


								DOME	ESTIC FIXT	TURE S	CHEDUL	.E				
ID	DESCRIPTION	MANUFACTURER	MODEL	QTY	TRIM			FLUSH FIXTURE WASTE					HOT WATER	WATER		
					MANUFACTURER	MODEL	TYPE	MOTION SENSOR CONTROL		ROUGH-IN WASTE PIPE SIZE			ROUGH-IN PIPE SIZE		REMARKS	
BT-1	BATH TUB	PRAXIS	RN6032	12	DELTA	R10000-PX	MANUAL	No		1-1/2"		1-1/2"	1/2"	1/2"	THE INDIVIDUAL DROP IN BATHTUB IS SPECIFIED IN ANOTHER DIVISION. PROVIDE DELTA RP53237 TUB SPOUT, PROVIDE A TUB DRAIN AS SPECIFIED IN "SOIL, WASTE, AND VENT PIPING SYSTEMS." SHOWER SYSTEM WITH ASSE 1016 COMPLIANT TYPE "T/P" THERMOSTATIC/PRESSURE BALANCING COMBINATION MIXING VALVE WITH ADJUSTABLE STOP SCREW TO LIMIT HANDLE TURN. PROVIDE MANUFACTURER'S FLOW RATE RESTRICTOR ON SHOWERHEAD.	
EWC-2	WATER COOLER - DUAL HEIGHT	ELKAY	EZSTL8WSSK	2				No		2"		1-1/2"	1/2"		TWO LEVEL WALL HUNG WATER COOLER WITH BOTTLE FILLING STATION. THE UNIT SHALL BE COMPLETE WITH CABINET, MOUNTING FRAME, SELF CLOSING EASY TOUCH SIDE AND FRONT PUSHBAR CONTROLS, FLEXIGUARD SAFETY BUBBLER, REFRIGERATING SYSTEM, AIR COOLED, 120 VOLT, 60 CYCLE, SINGLE PHASE POWER CONNECTION, FULLY AUTOMATIC, COMPLETE AND READY TO OPERATE.	
HB-1	HOSE BIBB	WOODFORD	B24-1/2	20			MANUAL	No					3/4"		INTERIOR HOSE BIBB WITH ANTI-SIPHON VACUUM BREAKER, 3/4" HOSE THREAD OUTLET, LOCK SHIELD CAP, AND REMOVABLE "TEE" HANDLE. PROVIDE SHUTOFF VALVE IN COLD WATER SUPPLY AHEAD OF HOSE BIBB.	
HB-2	HOSE BIBB-EXT	WOODFORD	MODEL 67	16			MANUAL	No					3/4"		Freezeless Wall Hydrant, 3/4" HOSE THREAD OUTLET, AND REMOVABLE "KEY" HANDLE. PROVIDE SHUTOFF VALVE IN COLD WATER SUPPLY AHEAD OF HOSE BIBB.	
HB-3	HOSE BIBB -ROOF	WOODFORD	RHY2-MS	8			MANUAL	No					3/4"		FREEZELESS ROOF HYDRANT WITH VACUUM BREAKER, DUAL CHECK BACKFLOW PREVENTER, 3/4" HOSE THREAD OUTLET, PROVIDE CAST IRON MOUNTING SUPPORT SYSTEM RH-MS. PROVIDE SHUTOFF VALVE IN COLD WATER SUPPLY AHEAD OF HOSE BIBB.	
JS-1	JANITOR SINK	MUSTEE	63M	8	MUSTEE	63.600A	MANUAL	No		3"		2"	3/4"	3/4"	SERVICE BASIN, 24"x24"X10" WITH CHROME PLATED 3" DRAIN AND CAST IRON TRAP. FAUCET SHALL INCLUDE PAIL HOOK AND ATMOSPHERIC VACUUM BREAKER SPOUT. FURNISH 65.700 SERVICE HOSE AND FITTINGS. SERVICE MOP HANGER	
K-1	KITCHEN w/DW	KOHLER	K3177	174	DELTA	9178-DST	MANUAL	No		1-1/2"		1-1/2"	1/2"	1/2"	DOUBLE COMPARTMENT UNDERMOUNT SINK, SWIVEL FAUCET. BASKET STRAINER, P-TRAP, TAILPIECES, SUPPLIES AND STOPS. PROVIDE TRAP AND CONNECTION TO DISHWASHER	
K-2	KITCHENETTE	KOHLER	K-5287	10	KOHLER	K-7509CP	MANUAL	No		1-1/2"		1-1/2"	1/2"	1/2"	SINGLE COMPARTMENT UNDERMOUNT SINK, SINGLE HOLE IN CASEWORK FOR FAUCET. BASKET STRAINER, P-TRAP, TAILPIECES, SUPPLIES AND STOPS. PROVIDE P-TRAP	
LAV-1	RESIDENTIAL LAVATORY - ADA	KOHLER	VERTICYL K2882-0	524	DELTA	#564-MPU-DST	MANUAL	No		2"		1-1/2"	1/2"	1/2"	UNDERMOUNT BATHROOM SINK, FAUCET HOLES ON 4" CENTERS IN CASEWORK. DECK-MOUNTED FAUCET, EXTERNAL ASSE 1070 COMPLIANT THERMOSTATIC MIXING VALVE, GRID DRAIN, P-TRAP.	
LAV-2	LAVATORY - ADA	KOHLER	VERTICYL K2882-0	8	AMERICAN STANDARD	6059.202	ELECTRONIC	Yes		2"		1-1/2"	1/2"	1/2"	UNDERMOUNT BATHROOM SINK, FAUCET HOLES ON 4" CENTERS IN CASEWORK. DECK-MOUNTED FAUCET, EXTERNAL ASSE 1070 COMPLIANT THERMOSTATIC MIXING VALVE, GRID DRAIN, P-TRAP.	
OB-5	ICE MAKER OUTLET BOX	SIOUX CHIEF	696-RG1010MF	178				No					1/2"		FULLY RECESSED FIRE RATED ICE MAKER SUPPLY BOX WITH COVER. PROVIDE 1/4 TURN BALL VALVES AND WATER HAMMER ARRESTORS IN BOX.	
OB-7	WASHING MACHINE OUTLET BOX	SIOUX CHIEF	696-R2313MF	174				No		2"		2"	1/2"	1/2"	FULLY RECESSED FIRE RATED WASHING MACHINE SUPPLY BOX WITH COVER. PROVIDE 1/4 TURN BALL VALVES AND WATER HAMMER ARRESTORS IN BOX. PROVIDE A 2" TRAPPED STANDPIPE IN CONCEALED WALL SPACE.	
SH-1	SHOWER STALL	BESTBATH	LB3SS6032CP	102	DELTA	SEE DETAIL	MANUAL	No		2"		1-1/2"	1/2"	1/2"	THE INDIVIDUAL SHOWER STALL AND ACCESSORIES IS SHOWN IN DETAIL BELOW SPECIFIED IN ANOTHER DIVISION. PROVIDE DELTA HAND SHOWER AND INTEGRATED DIVERTER. PROVIDE A SHOWER DRAIN AS SPECIFIED IN "SOIL, WASTE, AND VENT PIPING SYSTEMS." SHOWER SYSTEM WITH ASSE 10	
SH-2	SHOWER STALL	BESTBATH	LCS26540W75B	162	DELTA	SEE DETAIL	MANUAL	No		2"		1-1/2"	1/2"	1/2"	THE INDIVIDUAL SHOWER STALL AND ACCESSORIES IS SHOWN IN DETAIL BELOW SPECIFIED IN ANOTHER DIVISION. PROVIDE DELTA HAND SHOWER AND INTEGRATED DIVERTER. PROVIDE A SHOWER DRAIN AS SPECIFIED IN "SOIL, WASTE, AND VENT PIPING SYSTEMS." SHOWER S	
SH-3	SHOWER	TILE IN PLACE		16	DELTA	SEE DETAIL	MANUAL	No		1-1/2"		1-1/2"	1/2"	1/2"	THE INDIVIDUAL TILED SHOWER AND ACCESSORIES IS SPECIFIED IN ANOTHER DIVISION. PROVIDE A SHOWER DRAIN AS SPECIFIED IN "SOIL, WASTE, AND VENT PIPING SYSTEMS." SHOWER SYSTEM WITH ASSE 1016 COMPLIANT TYPE "T/P" THERMOSTATIC/PRESSURE BALANCING COMBINATION MIXING VALVE WITH ADJUSTABLE STOP SCREW TO LIMIT HANDLE TURN. PROVIDE MANUFACTURER'S FLOW RATE RESTRICTOR ON SHOWERHEAD.	
WC-1	RESIDENTIAL WATER CLOSET - FLR MT-TANK-ADA	ТОТО	DRAKE II CST454CEFG#01	386				No	1.28 gal	3"		2"	1/2"		The Two-piece low consumption Tornado Flush system toilet shall be 1.28GPF/4.8LPF. Toilet shall have optional CeFiONtect ceramic glaze and be at Universal Height. Toilet shall have high-profile tank, elongated front bowl and Chrome trip lever. SS224#01 SOFT CLOSE SEAT.	
WC-2	WATER CLOSET - FLR MNT-TANK-ADA	ТОТО	DRAKE II CST454CEFG#01	8				No	1.28 gal	3"		2"	1/2"		The Two-piece low consumption Tornado Flush system toilet shall be 1.28GPF/4.8LPF. Toilet shall have optional CeFiONtect ceramic glaze and be at Universal Height. Toilet shall have high-profile tank, elongated front bowl and Chrome trip lever. SC534-01 OPEN FRONT COMMERCIAL SEAT.	

SH-2 - SHOWER STALL

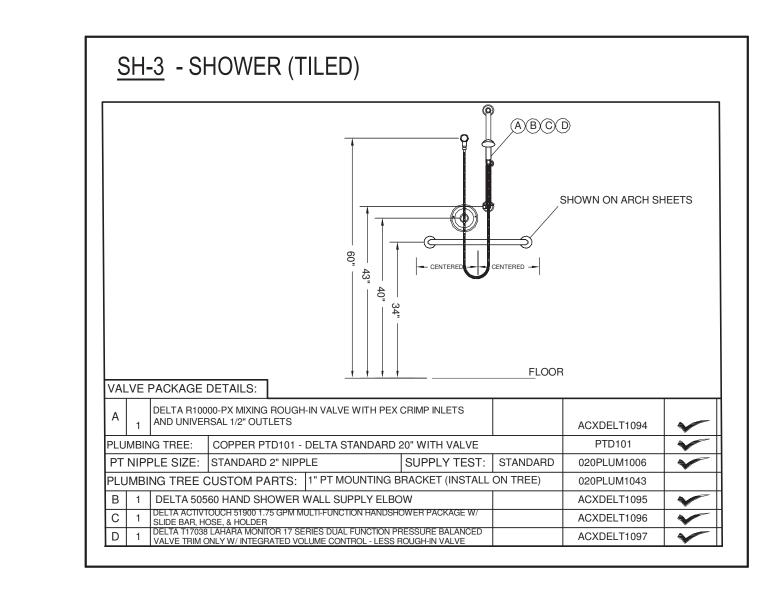

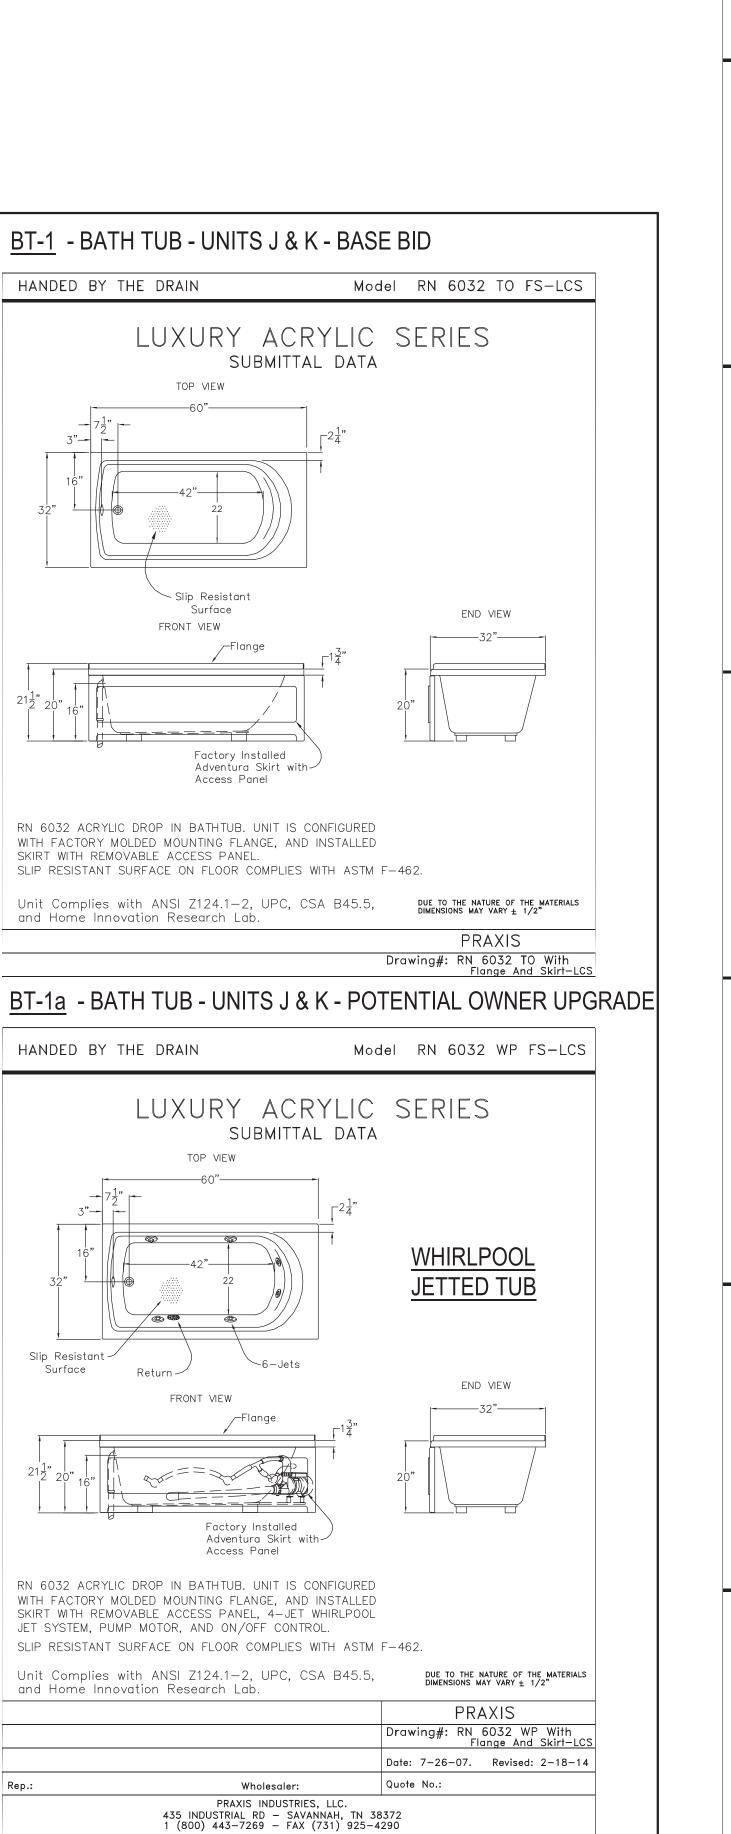

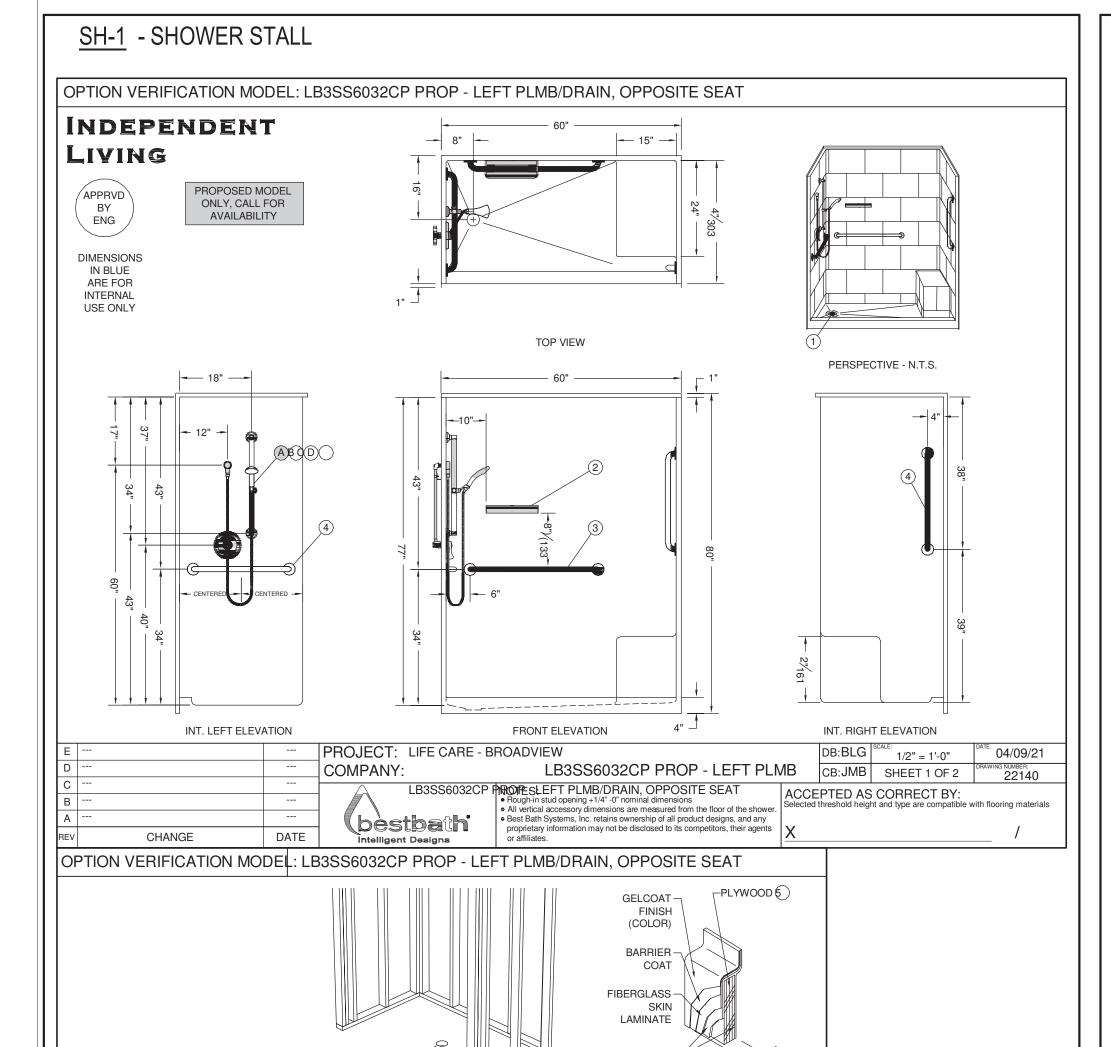

FIBERGLASS —

ACXDELT1094

ACXDELT1096

ACXDELT1097

PC WHITE GB24QSSW

COLOR PART NUMBER

REFER TO SHEET 1 OF 2 FOR ACCESSORY LOCATIONS

POLISHED ACXSD13PS

KACXDRAIN2000

FRAMING POCKET REQUIREMENTS

FOR THE PROTECTION OF YOUR ACCESSORIES, SOME ITEMS INCLUDED IN THE VALVE PACKAGE WILL NOT BE INSTALLED AT THE FACTORY.

THESE ITEMS INCLUDE, BUT ARE NOT LIMITED TO, THE SUPPLY ELBOW, VACUUM BREAKER, HOSE, AND HAND SHOWER.

SUPPLY TEST: STANDARD 020PLUM1006

VALVE PACKAGE DETAILS:

AND UNIVERSAL 1/2" OUTLETS

PT NIPPLE SIZE: STANDARD 2" NIPPLE

- FULL PLYWOOD BACKING

(bestbath

DELTA R10000-PX MIXING ROUGH-IN VALVE WITH PEX CRIMP INLETS

SLIDE BAR, HOSE, & HOLDER
DELTA T17038 LAHARA MONITOR 17 SERIES DUAL FUNCTION PRESSURE BALANCED

STANDARD NO CAULK BRASS DRAIN WITH POLISHED STAINLESS STEEL SCREEN AND

DESCRIPTION

PLUMBING TREE CUSTOM PARTS: 1" PT MOUNTING BRACKET (INSTALL ON TREE) 020PLUM1043

PARTS LIST

PLUMBING TREE: COPPER PTD101 - DELTA STANDARD 20" WITH VALVE

B 1 DELTA 50560 HAND SHOWER WALL SUPPLY ELBOW

2 24" x 1-¼" GRAB BAR - POWDER COATED WHITE

1 13" WALL MOUNTED SOAP DISH, POLISHED


OATEY 42157 GASKET FOR NO-HUB CAST IRON PIPE


32" x 1-14" GRAB BAR - POWDER COATED WHITE

LAMINATE ½" MIN.—

LAMINATE DETAIL C - SCALE: 3" = 1'-0"

04/09/21

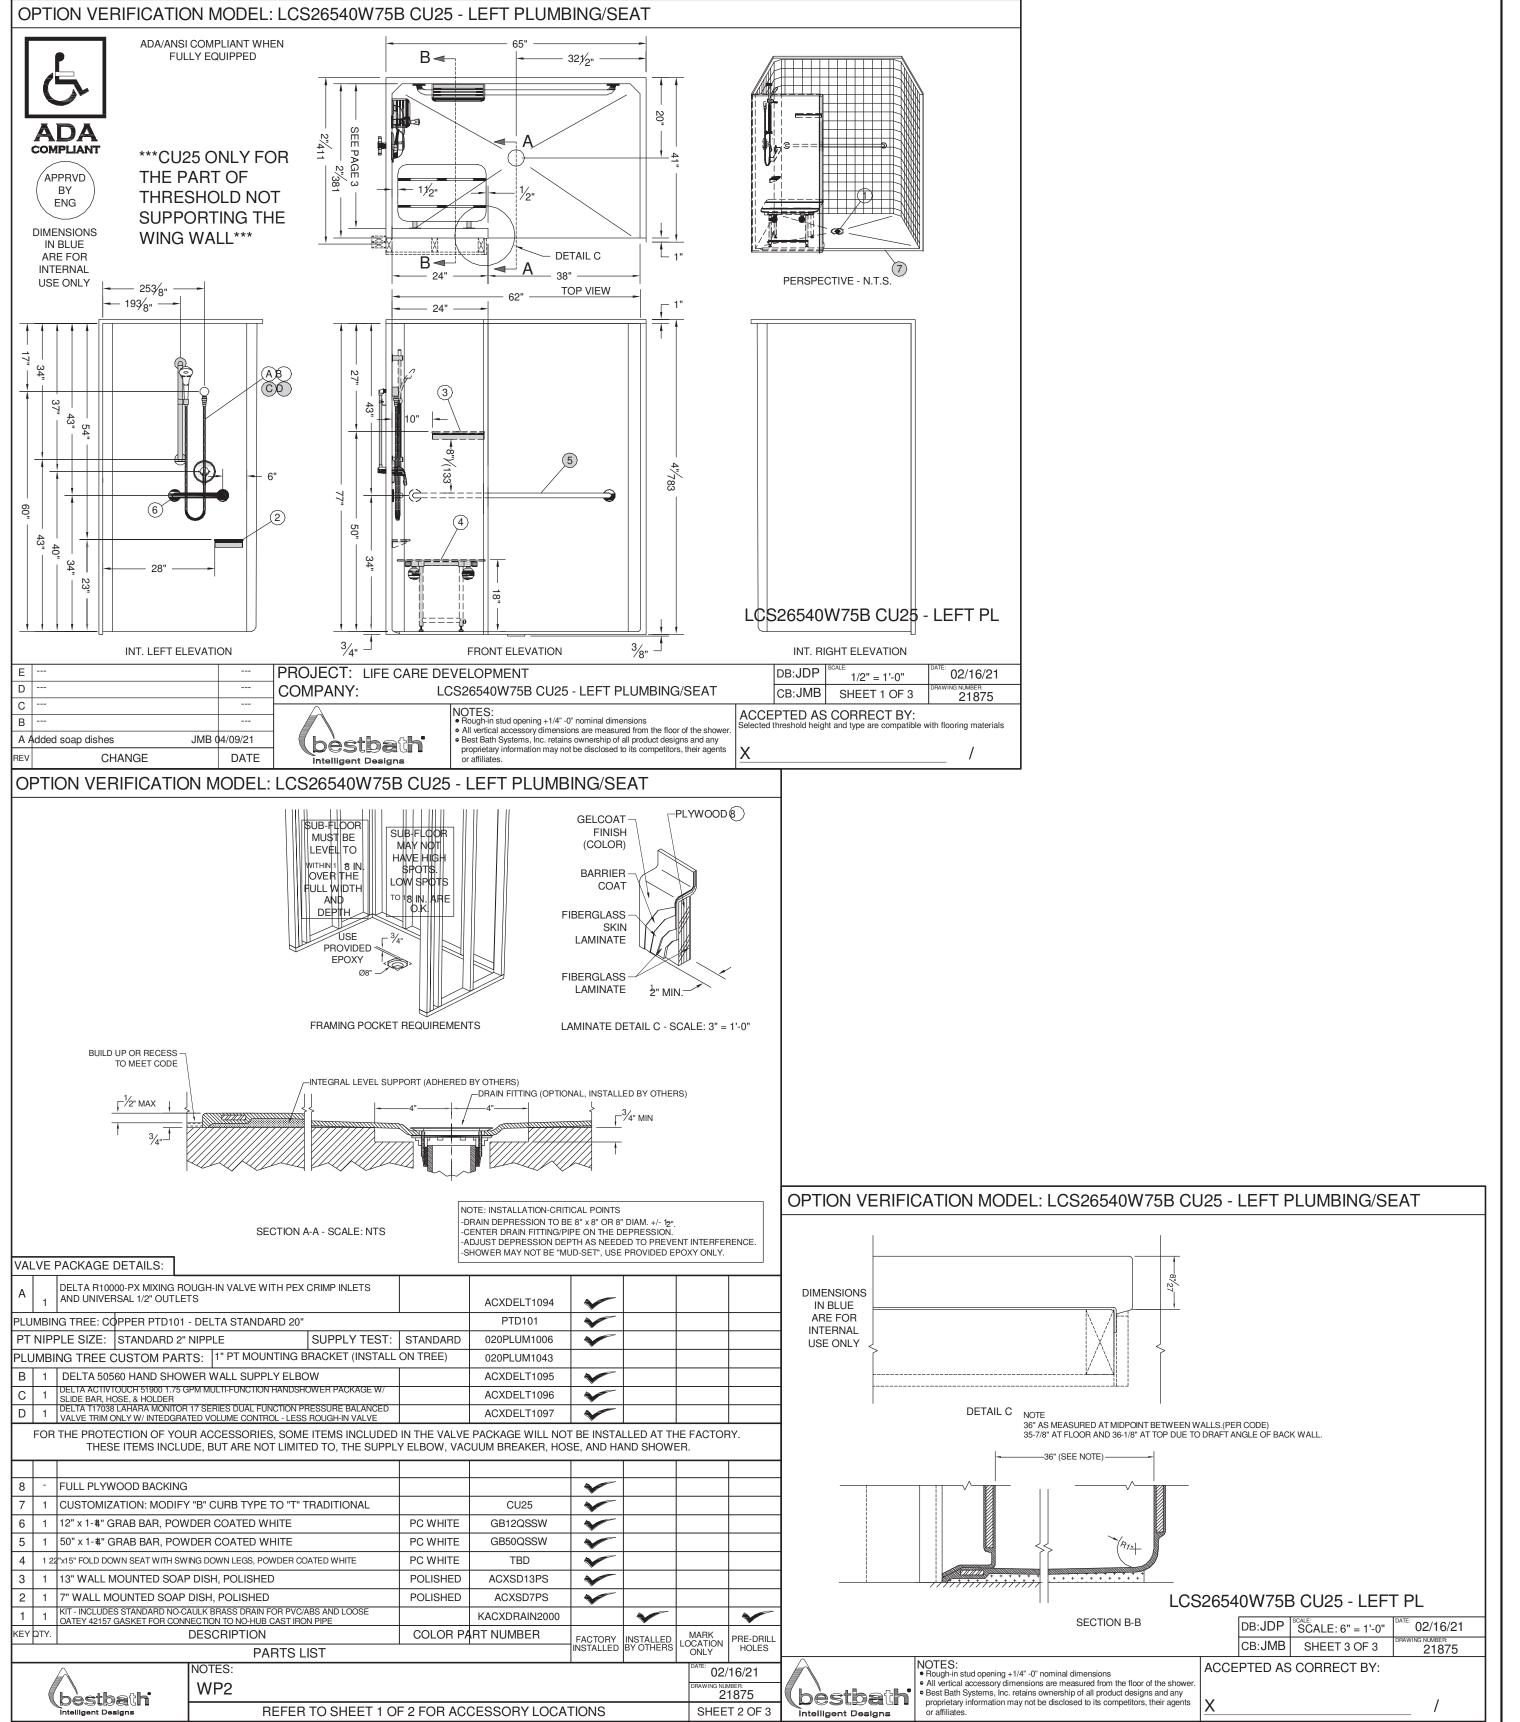

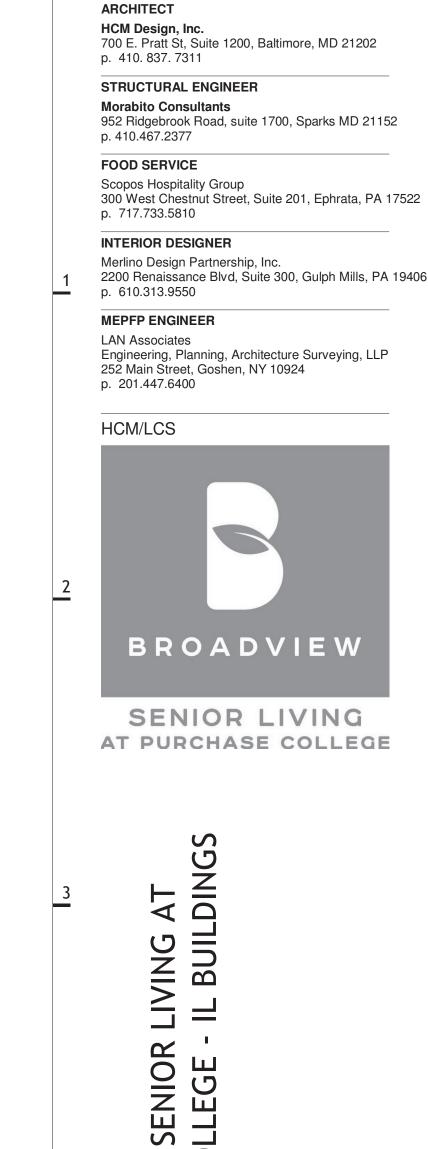

hord coplan macht

ARCHITECTURE

LANDSCAPE ARCHITECTURE

PLANNING

INTERIOR DESIGN



LAN ASSOCIATES
Engineering, Planning, Architecture, Surveying, LLP
LAN JOB #1308.01
PROFESSIONAL CERTIFICATION: I CERTIFY THAT THESE DOCUMENTS WERE
PREPARED OR APPROVED BY ME, AND THAT I AM A DULY LICENSED ENGINEER
UNDER THE LAWS OF THE STATE OF NEW YORK.
LICENSE NUMBER: 090385
EXPIRATION DATE: 10/31/23

		_
no.	date	revision
Project	Name	
BROAD	VIEW - S	ENIOR LIVING AT PURCHASE
	GE - IL BI	

Project Name
BROADVIEW - SENIOR LIVING AT PURCHASE
COLLEGE - IL BUILDINGS
Project Number
4.1308.01

Date

Date
4/30/2021

Scale
1/8" = 1'-0"

)/ O1

PLUMBING SCHEDULE AND

DERMIT / GMP SET

DETAILS

PERMIT / GMP SET

© Hord Coplan Macht, Inc.

f B f C f B f K f B