

[illegible]

CLIENT
**Montebello Realty
GP LLC**

**Montebello Crossing,
250 Lafayette Avenue
(Route 59)
Village of Montebello
New York**

STATUS	FOR CONSTRUCTION
--------	------------------

DRAWING No. **H0 1** SHEET No. 

23. IT IS THE INTENT OF THESE PLANS AND SPECIFICATIONS TO PROVIDE ALTERATIONS AND/OR NEW CONSTRUCTION AS INDICATED ON THE DRAWINGS AND IN THE SPECIFICATIONS TO PROVIDE COMPLETE NEW SYSTEMS IN EVERY RESPECT, CAPABLE OF OPERATING AS DESIGNED. IT IS NOT INTENDED THAT EVERY FITTING, MINOR DETAIL OR FEATURE BE SHOWN ON DRAWINGS. THE CONTRACTOR SHALL BE RESPONSIBLE FOR ANY DETAIL NECESSARY FOR COMPLETION OF THESE SYSTEMS IN ACCORDANCE WITH GOOD PRACTICE.

File Name: C:\Users\ah\AppData\Local\Temp\AcPublish_3704\H0.1.dwg (Layout: Layout1)
Date: Mon, Aug 08, 2022 - 9:29 AM (Name: ah)


DESIGNED BY:		DRAWN BY:		CHECKED BY:		REVIEWED BY:	
ECR		SRB		EDF		MDF	
PROJECT NO: FLB 1501 DATE: 11/15/19 SCALE: AS SHOWN							

**Montebello Crossing,
250 Lafayette Avenue
(Route 59)
Village of Montebello
New York**

SHEET TITLE

**MEP:
SITE PLAN**

SHEET No. _____
OF _____

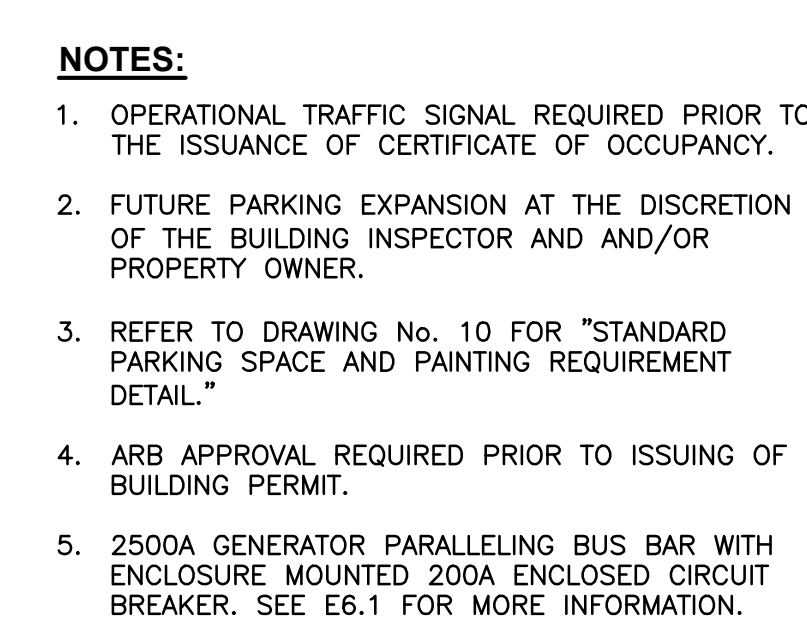

1 MEP SITE PLAN
SCALE: 1"=40'

**Broad Hollow Road, 4th Floor East
Melville, NY 11747
631.756.8000 • www.h2m.com**

CONSULTANTS:

FELLENZER III
ENGINEERING LLP

22 Mulberry St., Suite 2A,
Middletown, NY 10940
t 845-343-1481 fx 855-320-8735

www.fellp.com
Project #: 15-345

[illegible]

REPRODUCTION OF THIS DOCUMENT WITHOUT THE WRITTEN PERMISSION OF THE PROFESSIONAL IS ILLEGAL			
DESIGNED BY: PMC	DRAWN BY: SRB	CHECKED BY: EDF	REVIEWED BY: 0
PROJECT No: FILB 1501	DATE: 11/15/19	SCALE: AS SHOWN	

**Montebello Realty
GP LLC**

Braemar at Montebello Assisted Living Residence

**Montebello Crossing,
250 Lafayette Avenue
(Route 59)
Village of Montebello
New York**

CONTRACT	
----------	--

FOR CONSTRUCTION

SHEET TITLE

**HVAC PARTIAL
BASEMENT FLOOR DUCT
& DIFFUSER PLAN - AREA
A**


DRAWING No. **H2.0A**



"ALTERNATION OF THIS DOCUMENT EXCEPT BY A LICENSED PROFESSIONAL IS ILLEGAL."			
DESIGNED BY: PMC	DRAWN BY: SRB	CHECKED BY: EDF	REVIEWED BY: o
PROJECT No: FILB 1501	DATE: 11/15/19	SCALE: AS SHOWN	

**Montebello Crossing,
250 Lafayette Avenue
(Route 59)
Village of Montebello
New York**

 SHEET No. _____



H2architects
+
Mengineers

538 Broad Hollow Road, 4th Floor East
Melville, NY 11747
631.756.8000 • www.h2m.com

CONSULTANTS:
FELLENZER III
ENGINEERING LLP
22 Mulberry St., Suite 2A,
Middletown, NY 10940
t 845-343-1481 fx 855-320-8735 Project #: 15-345

MARK	DATE	DESCRIPTION
	01/24/20	FINAL BID / PERMIT
	04/15/22	90% V.E. SUBMISSION
	06/03/22	ISSUE FOR BID
1	07/22/22	ADDENDUM #1
	08/08/22	ISSUED FOR CONSTRUCTION

MARK	DESCRIPTION
A	
A.8	
B	
C	

DESIGNED BY: **PMC**
PROJECT No: **FILB 1501**

DRAWN BY: **SRB**
DATE: 11/15/19

CHECKED BY: **EDF**
SCALE: AS SHOWN

REVIEWED BY:

CLIENT
**Montebello Realty
GP LLC**

**Braemar at Montebello Assisted
Living Residence**

**Montebello Crossing,
250 Lafayette Avenue
(Route 59)
Village of Montebello
New York**

CONTRACT

STATUS
FOR CONSTRUCTION

SHEET TITLE
**HVAC PARTIAL FIRST
FLOOR DUCT & DIFFUSER
PLAN - AREA A**

DRAWING No.
H2.1A

SHEET No.
OF

1 HVAC FIRST FLOOR DUCT & DIFFUSER PLAN - PART A
SCALE: 1/8" = 1'-0"

H2architects
+
engineers

538 Broad Hollow Road, 4th Floor East
Melville, NY 11747
631.756.8000 • www.h2m.com

CONSULTANTS:
FELLENZER III
ENGINEERING LLP
22 Mulberry St., Suite 2A,
Middletown, NY 10940
t 845-343-1481 fx 855-320-8735 Project #: 15-345

MARK	DATE	DESCRIPTION
	01/24/20	FINAL BID / PERMIT
	04/15/22	90% V.E. SUBMISSION
	06/03/22	ISSUE FOR BID
1	07/22/22	ADDENDUM #1
	08/08/22	ISSUED FOR CONSTRUCTION

DESIGNED BY: **PMC**
PROJECT No: **FILB 1501**

DRAWN BY: **SRB**
DATE: 11/15/19

CHECKED BY: **EDF**
SCALE: AS SHOWN

REVIEWED BY:

CLIENT
**Montebello Realty
GP LLC**

**Braemar at Montebello Assisted
Living Residence**

**Montebello Crossing,
250 Lafayette Avenue
(Route 59)
Village of Montebello
New York**


CONTRACT

STATUS
FOR CONSTRUCTION

SHEET TITLE
**HVAC PARTIAL FIRST
FLOOR DUCT & DIFFUSER
PLAN - AREA B**

DRAWING No.
H2.1B

SHEET No.
OF

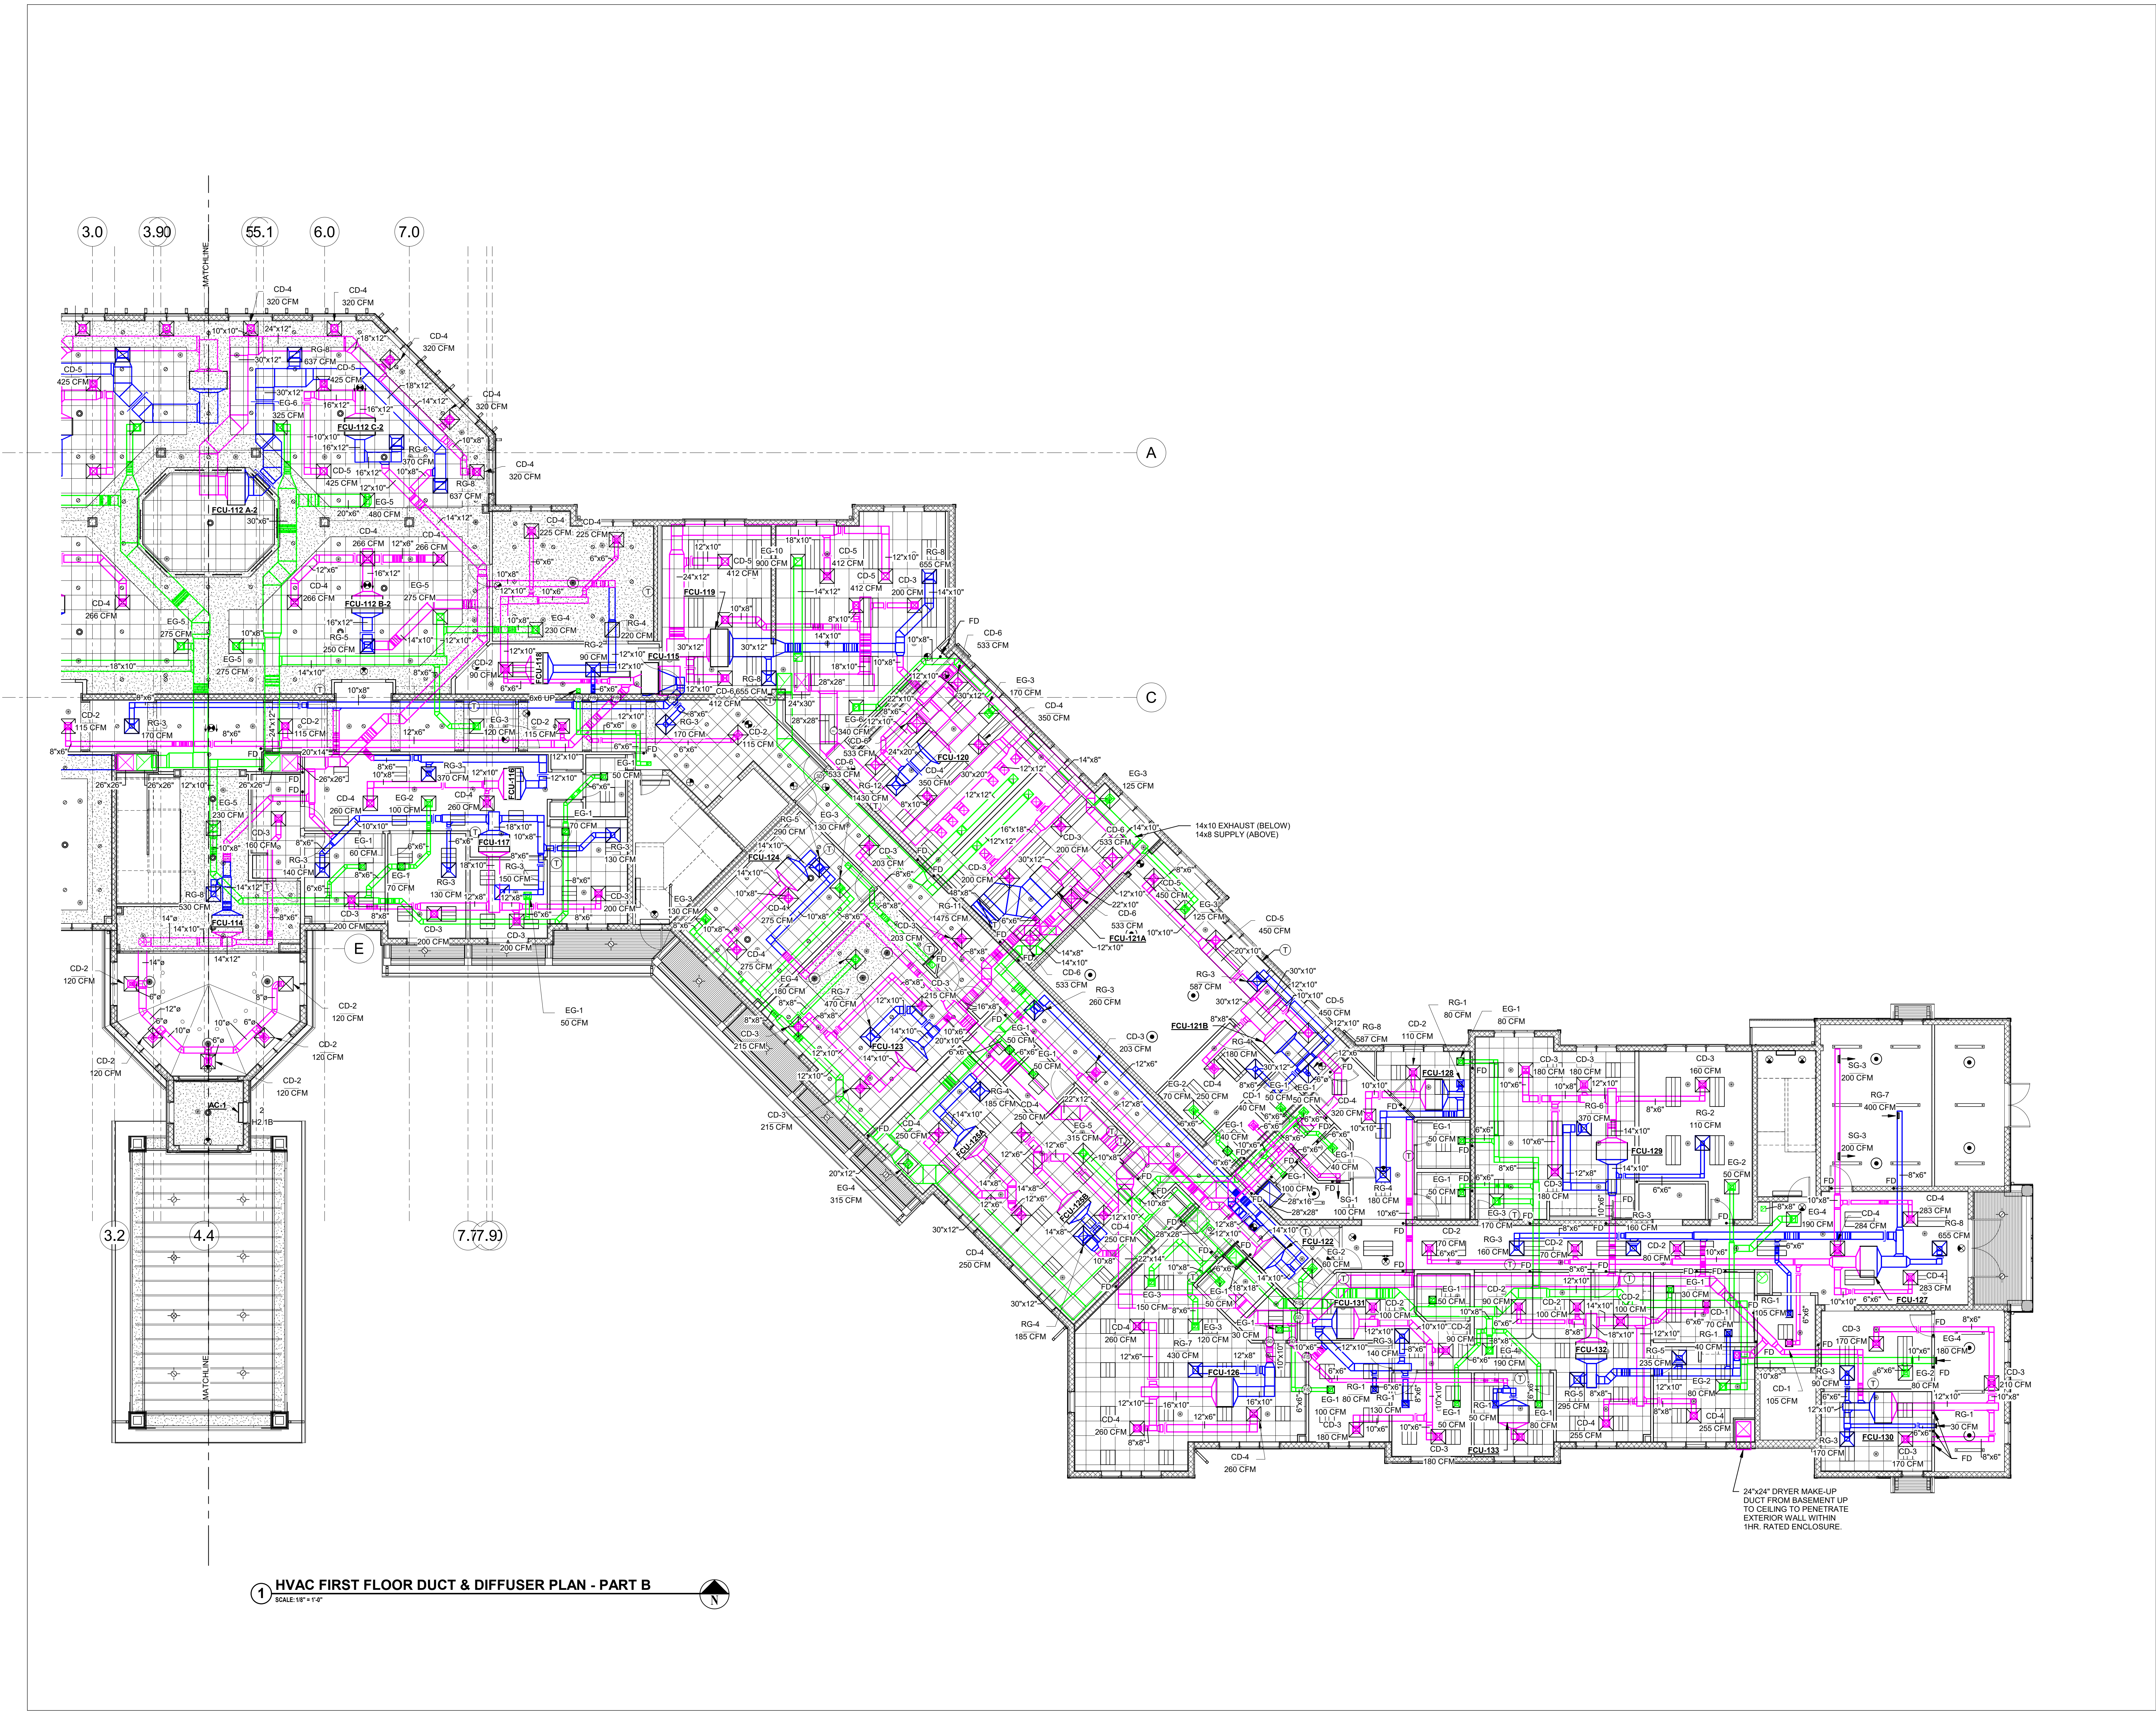

CONSULTANTS:

FELLENZER III
ENGINEERING LLP

22 Mulberry St., Suite 2A,
Middletown, NY 10940
t 845-343-1481 fx 855-320-8735

MARK	DATE	DESCRIPTION
	01/24/20	FINAL BID / PERMIT
	04/15/22	90% V.E. SUBMISSION
	06/03/22	ISSUE FOR BID
1	07/22/22	ADDENDUM #1
	08/08/22	ISSUED FOR CONSTRUCTION

ALTERATION OF THIS DOCUMENT EXCEPT BY A LICENSED PROFESSIONAL IS ILLEGAL.			
DESIGNED BY: PMC	DRAWN BY: SRB	CHECKED BY: EDF	REVIEWED BY: o
PROJECT No: FILB 1501	DATE: 11/15/19	SCALE: AS SHOWN	

CLIENT **Montebello Realty
GP LLC**

**Braemar at Montebello Assisted
Living Residence**

**Montebello Crossing,
250 Lafayette Avenue
(Route 59)
Village of Montebello
New York**

CONTRACT

STATUS	FOR CONSTRUCTION
--------	------------------

SHEET TITLE

**HVAC PARTIAL SECOND
FLOOR DUCT & DIFFUSER
PLAN - AREA A**


DRAWING No.	SHEET No.
-------------	-----------

H2.2A

SHEET No.


Year	Actual (%)	Projected (%)
1950	7.5	-
1960	8.5	-
1970	9.5	-
1980	10.5	-
1990	11.5	-
2000	12.5	12.5
2010	-	14.5
2020	-	16.5
2030	-	17.5
2040	-	18.0
2050	-	18.5

C:\Users\ah\Desktop\Revit Local Files\15-345A MONTEBELLO\17-0206 FILB\501_Central\17_M (LOCAL FILE 2021).rvt

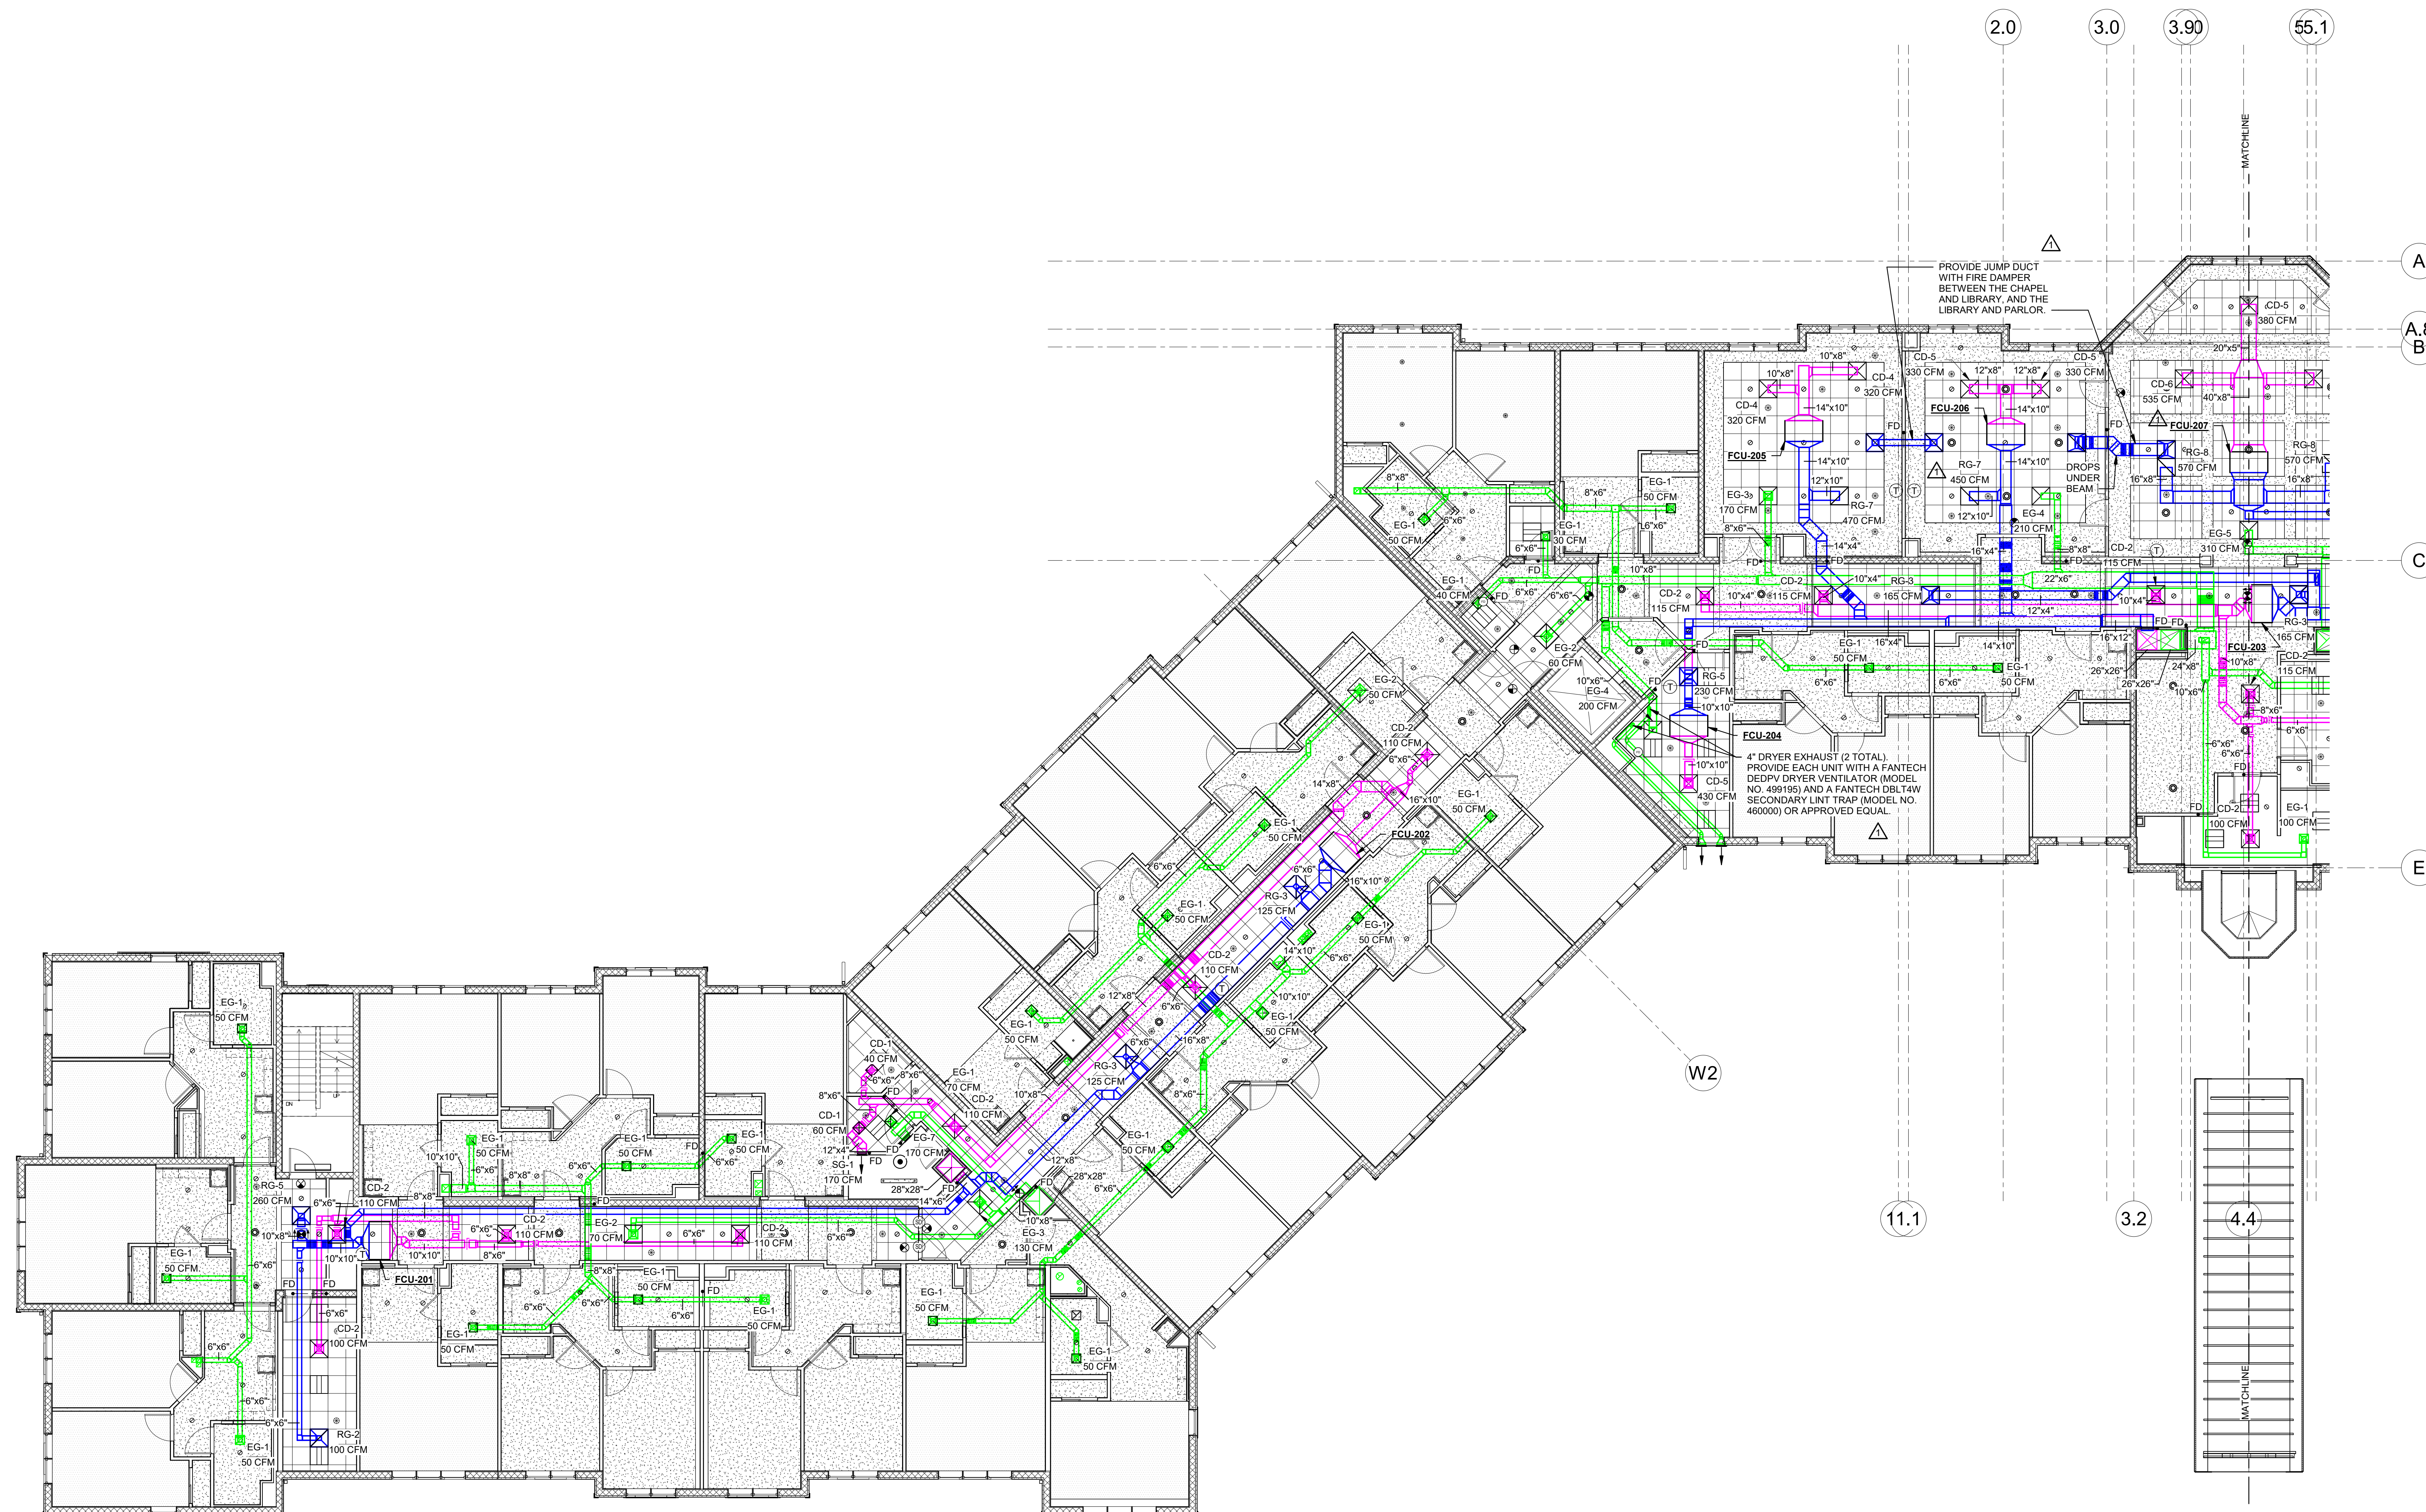

1 HVAC SECOND FLOOR DUCT & DIFFUSER PLAN - PART A
SCALE: 1/8" = 1'-0"



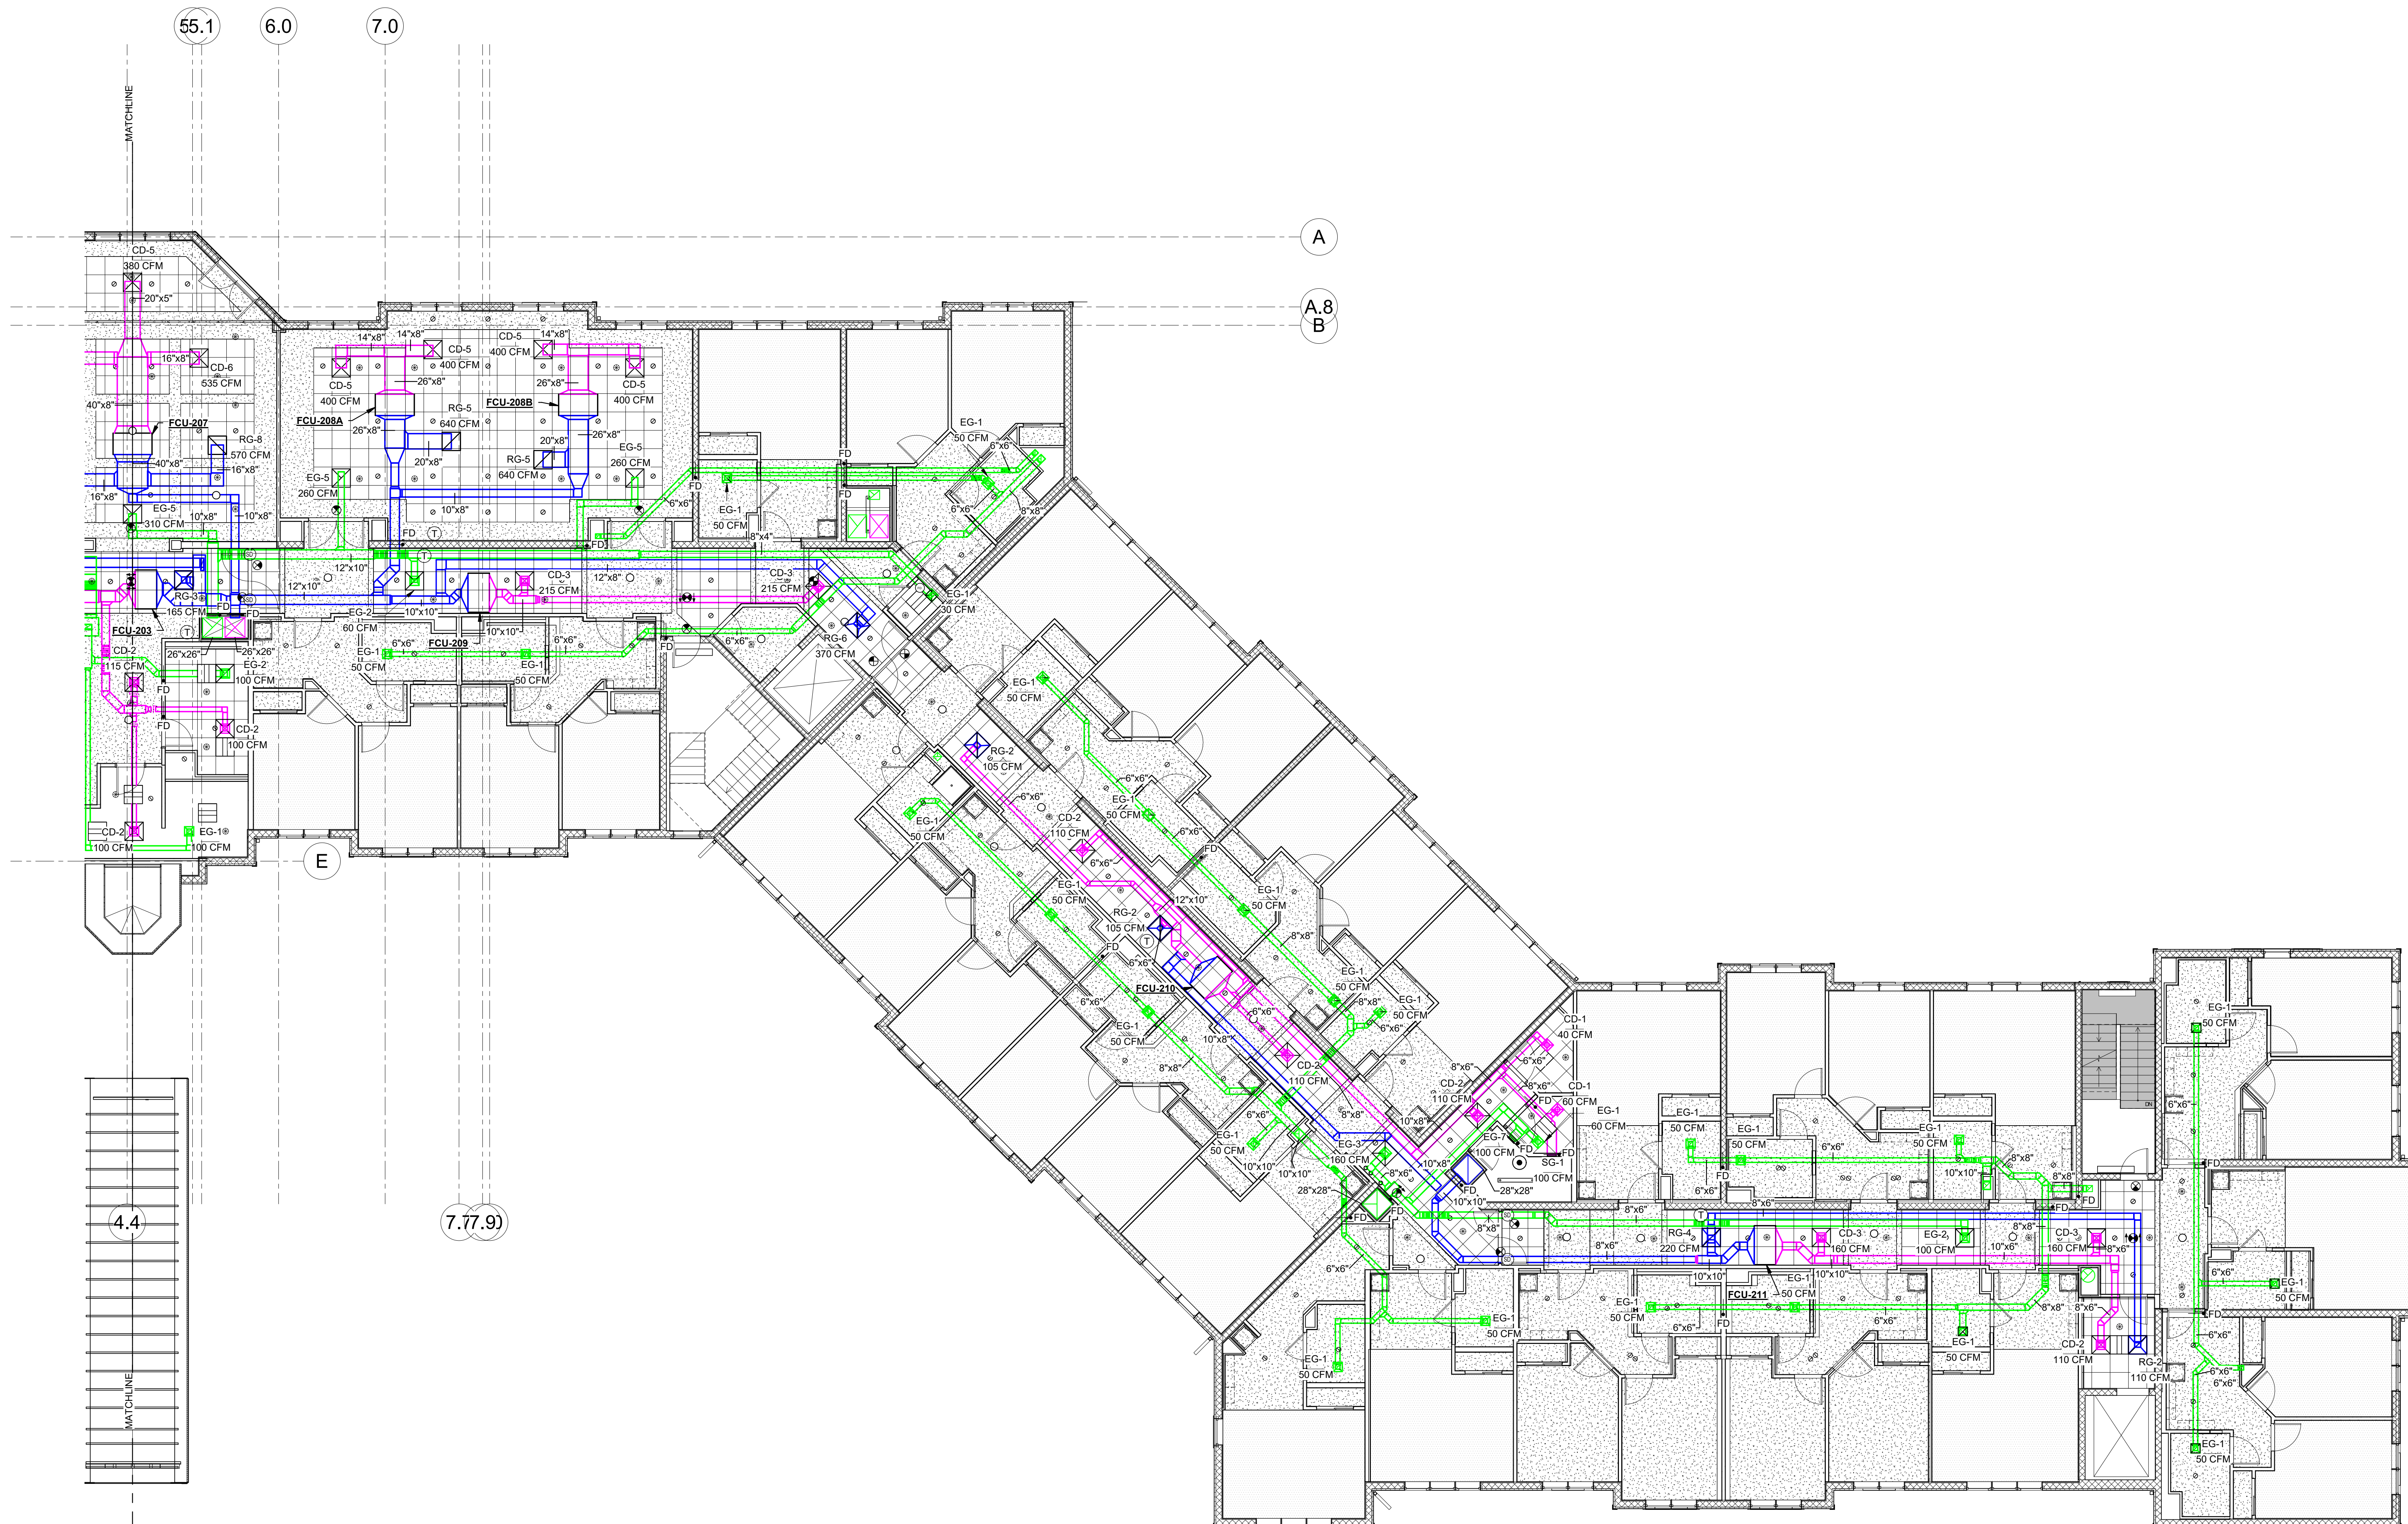

1 HVAC SECOND FLOOR DUCT & DIFFUSER PLAN - PART B
SCALE: 1/8" = 1'-0"

MARK	DATE	DESCRIPTION
	01/24/20	FINAL BID / PERMIT
	04/15/22	90% V.E. SUBMISSION
	06/03/22	ISSUE FOR BID
1	07/22/22	ADDENDUM #1
	08/08/22	ISSUED FOR CONSTRUCTION

DESIGNED BY: PMC	DRAWN BY: SRB	CHECKED BY: EDF	REVIEWED BY:
PROJECT No: FILB 1501	DATE: 11/15/19	SCALE: AS SHOWN	

CLIENT
**Montebello Realty
GP LLC**

**Braemar at Montebello Assisted
Living Residence**


**Montebello Crossing,
250 Lafayette Avenue
(Route 59)
Village of Montebello
New York**

CONTRACT

STATUS
FOR CONSTRUCTION

SHEET TITLE
**HVAC PARTIAL THIRD
FLOOR DUCT & DIFFUSER
PLAN - AREA A**

DRAWING No.
H2.3A
SHEET No.
OF

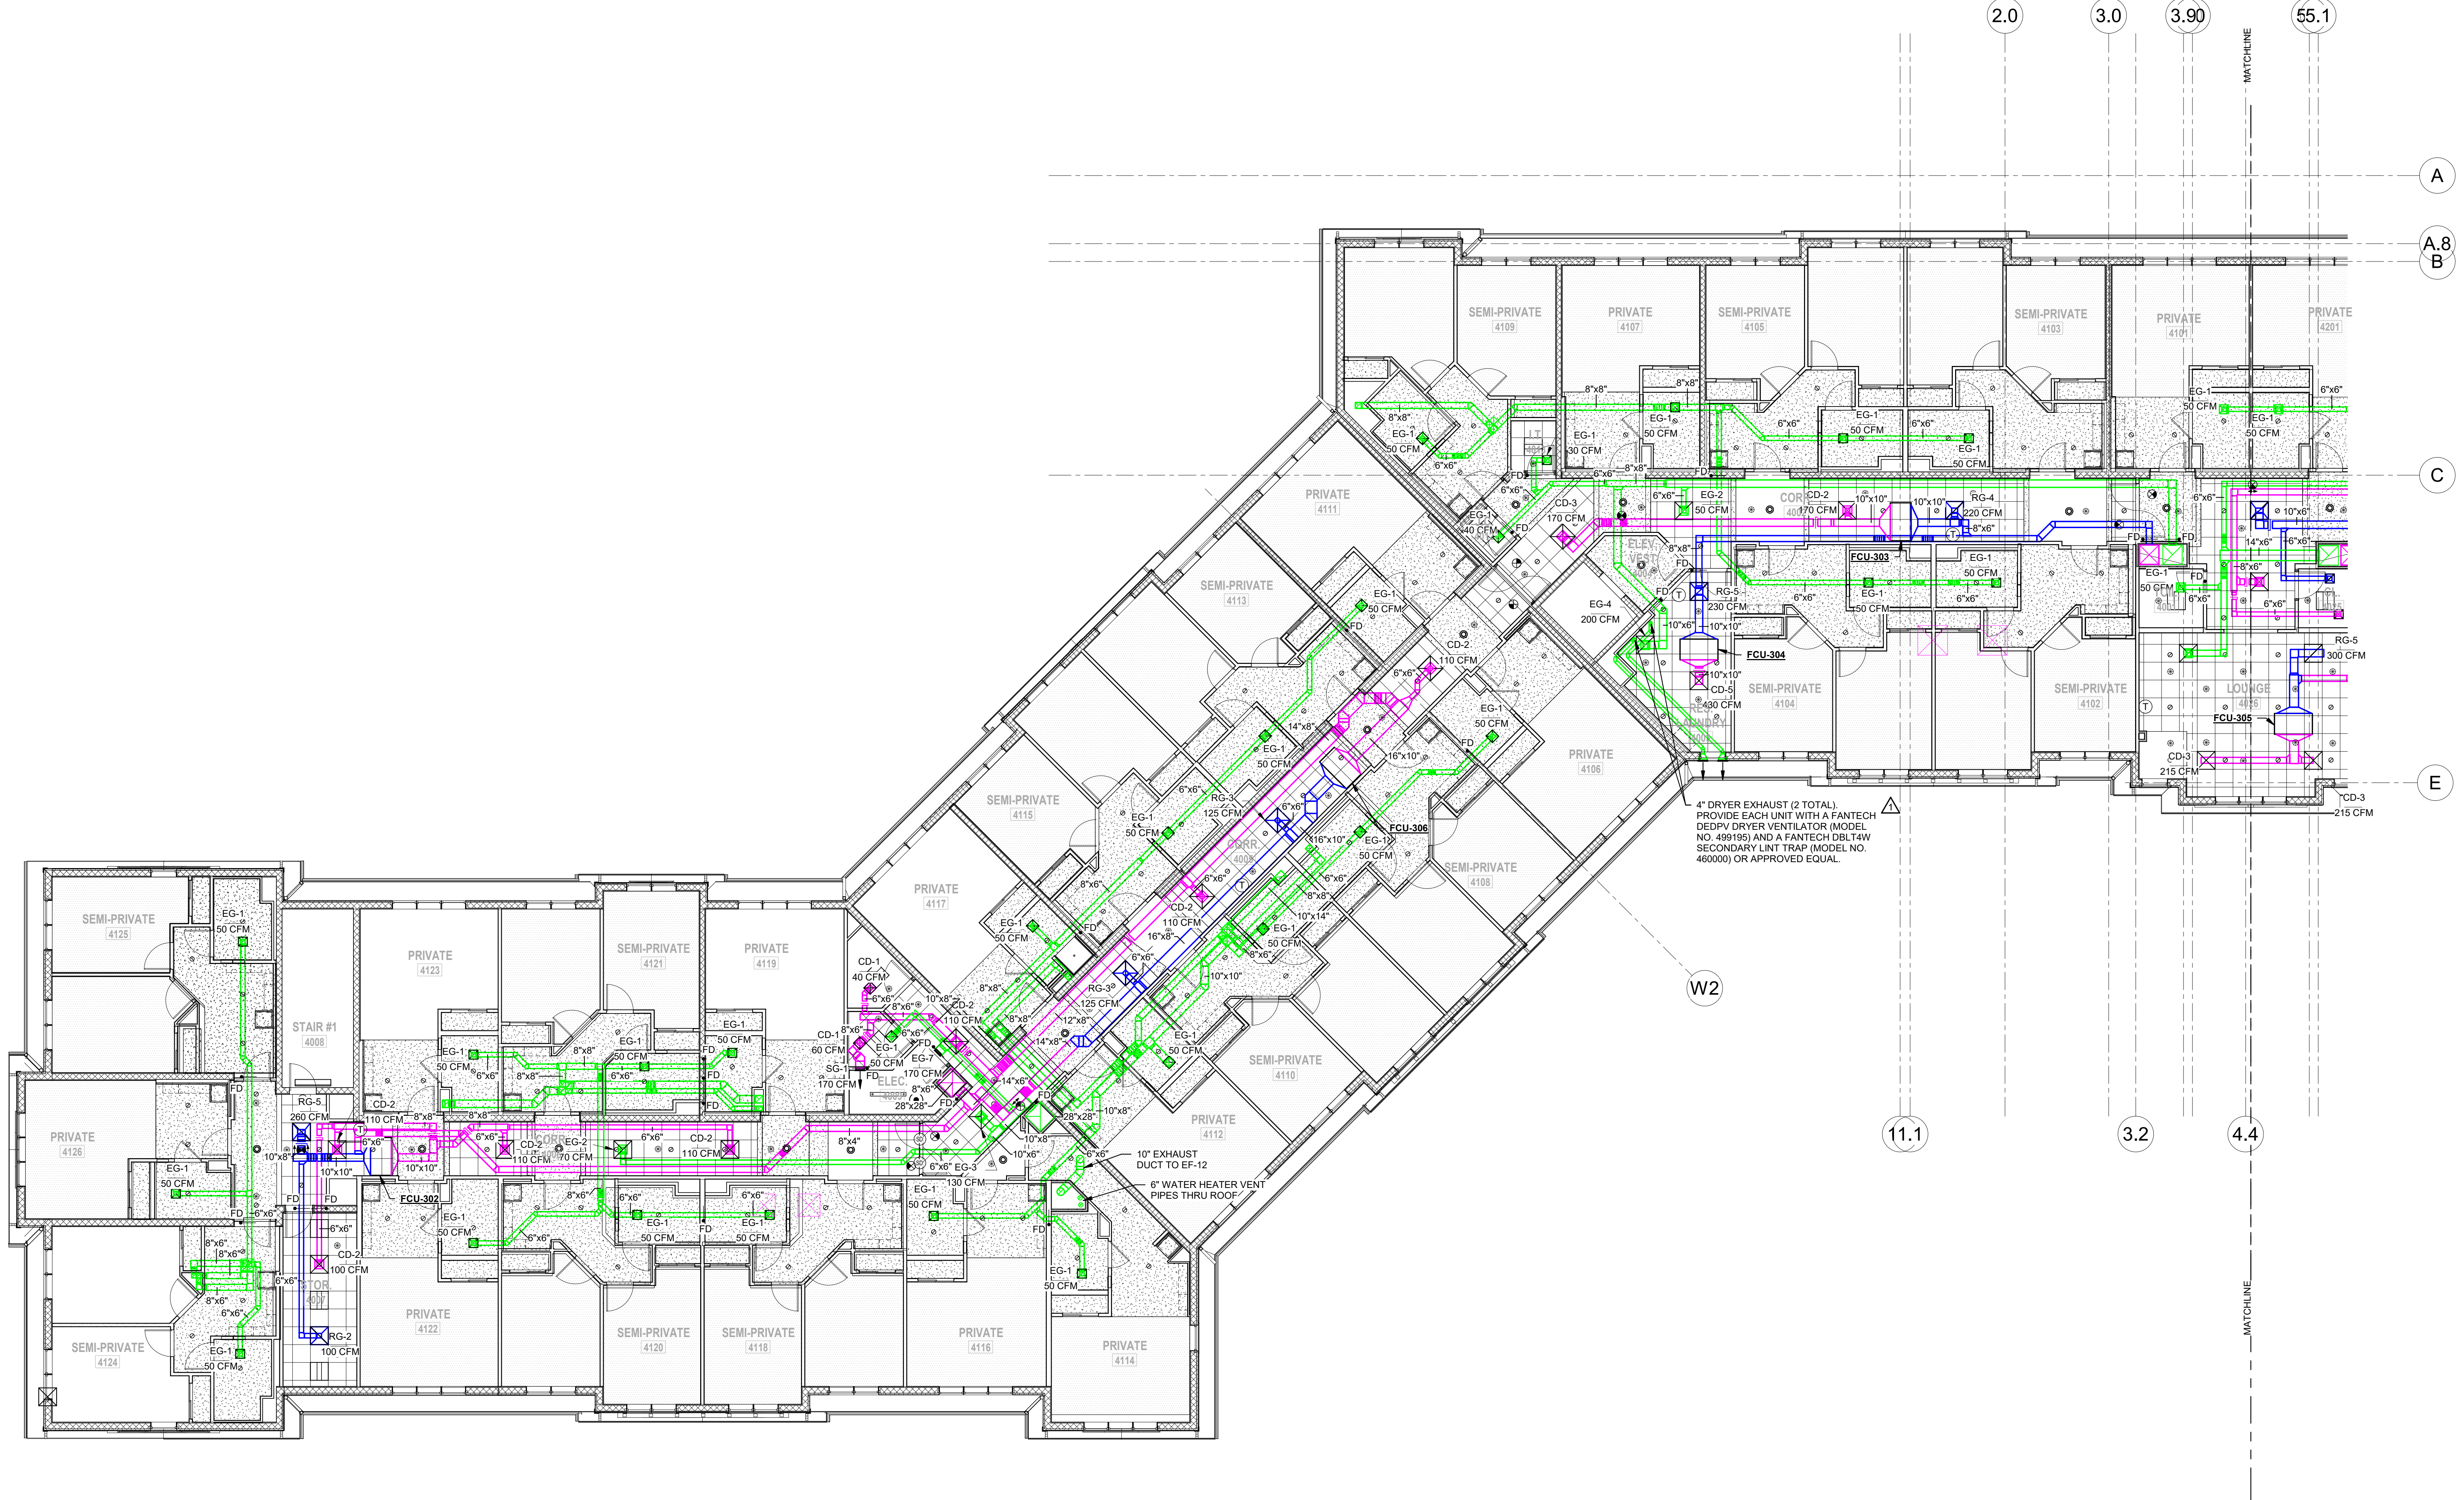

H2architects
+
engineers

538 Broad Hollow Road, 4th Floor East
Melville, NY 11747
631.756.8000 • www.h2m.com

CONSULTANTS:
FELLENZER III
ENGINEERING LLP
22 Mulberry St., Suite 2A,
Middletown, NY 10940
t 845-343-1481 fx 855-320-8735 Project #: 15-345

MARK	DATE	DESCRIPTION
	01/24/20	FINAL BID / PERMIT
	04/15/22	90% V.E. SUBMISSION
	06/03/22	ISSUE FOR BID
1	07/22/22	ADDENDUM #1
	08/08/22	ISSUED FOR CONSTRUCTION

DESIGNED BY:
PMC

DRAWN BY:
SRB

CHECKED BY:
EDF

REVIEWED BY:

PROJECT No:
FILB 1501

DATE:
11/15/19

SCALE:
AS SHOWN

CLIENT
**Montebello Realty
GP LLC**

**Braemar at Montebello Assisted
Living Residence**

**Montebello Crossing,
250 Lafayette Avenue
(Route 59)
Village of Montebello
New York**

CONTRACT

STATUS
FOR CONSTRUCTION


SHEET TITLE
**HVAC PARTIAL THIRD
FLOOR DUCT & DIFFUSER
PLAN - AREA B**

DRAWING No.
H2.3B

SHEET No.
OF

C:\Users\sl\Desktop\Revit Local Plans\15-345A MONTBELLO\17-0208 FILB 1501_Constrn17_A\LOCAL FILE 2023\1A.V1T

8/8/2023 9:17:57 AM

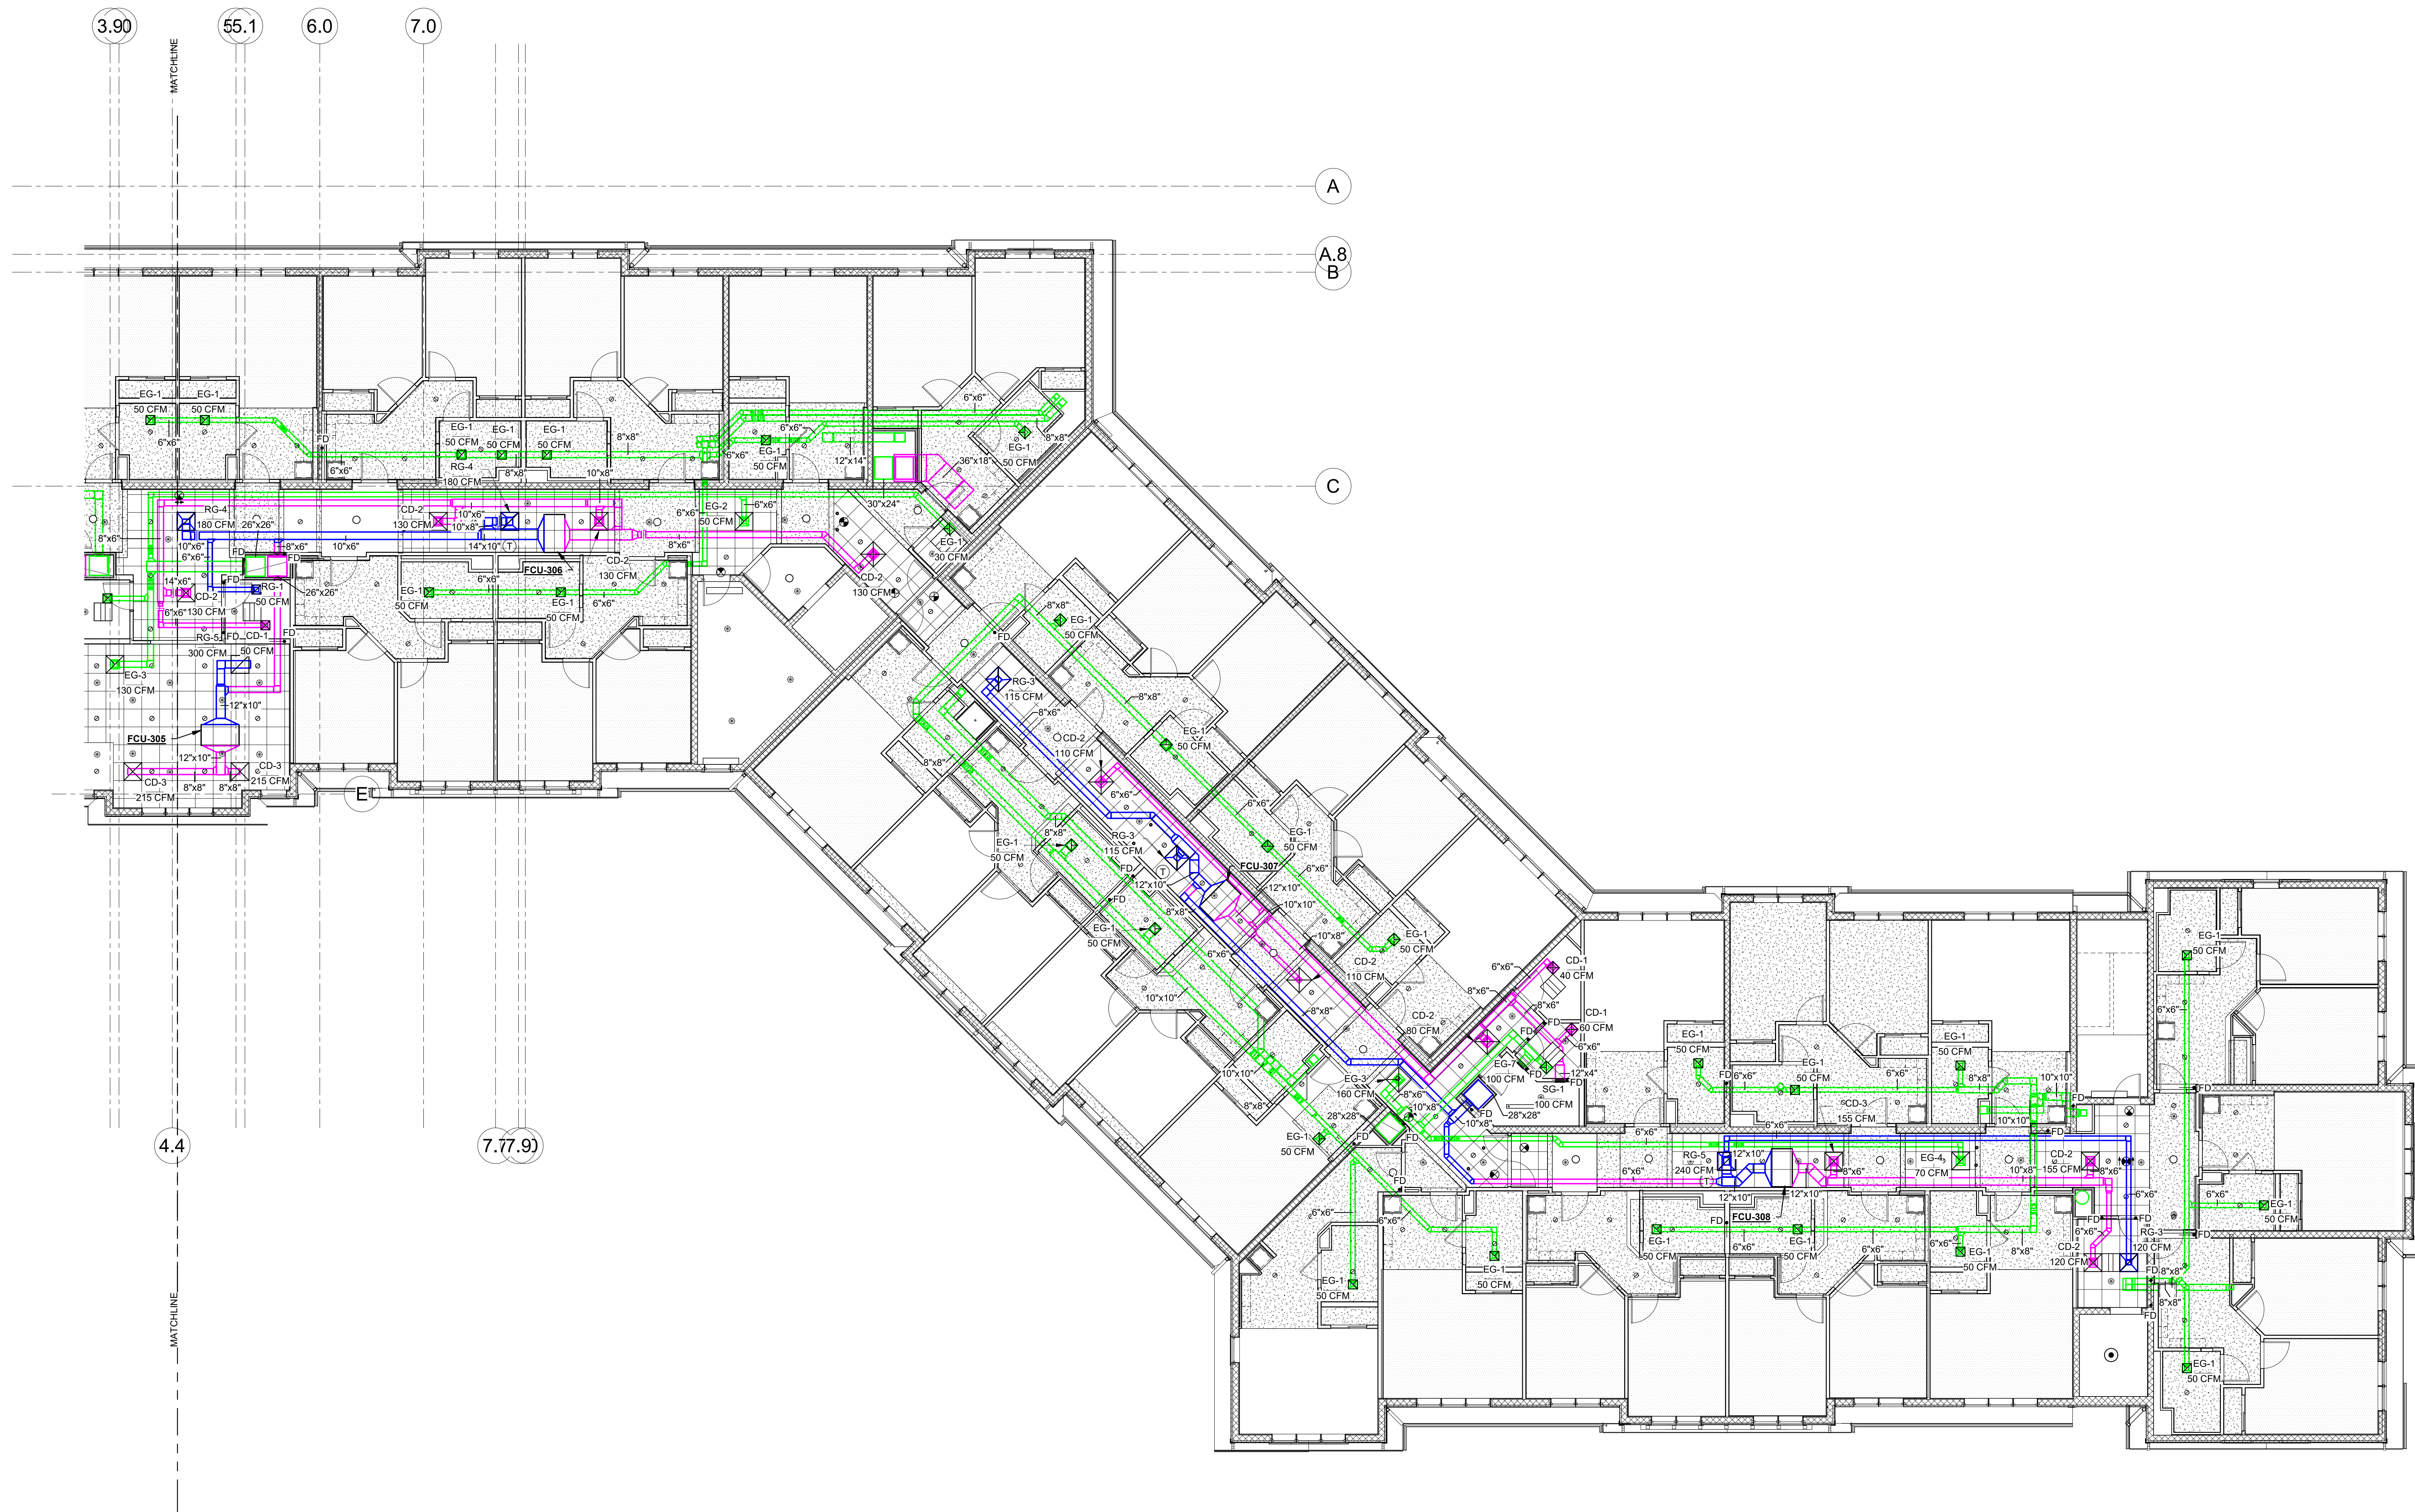

1 HVAC THIRD FLOOR DUCT & DIFFUSER PLAN - PART B
SCALE: 1/8" = 1'-0"

538 Broad Hollow Road, 4th Floor East
Melville, NY 11747
631.756.8000 • www.h2m.com

www.fellp.com

**22 Mulberry St., Suite 2A,
Middletown, NY 10940**
t 845-343-1481 fx 855-320-8735

[illegible]

"AL ALTERATION OF THIS DOCUMENT EXCEPT BY A LICENSED PROFESSIONAL IS ILLEGAL."			
DESIGNED BY: PMC	DRAWN BY: SRB	CHECKED BY: EDF	REVIEWED BY: o
PROJECT No: FILB 1501		DATE: 11/15/19	SCALE: AS SHOWN

**Montebello Realty
GP LLC**

**Maramar at Montebello Assisted
Living Residence**


**Montebello Crossing,
250 Lafayette Avenue
(Route 59)
Village of Montebello
New York**

CONTRACT

FOR CONSTRUCTION

HVAC WATER HEATER & MECHANICAL ROOM ENLARGED PLAN

SHEET No. _____
OF _____

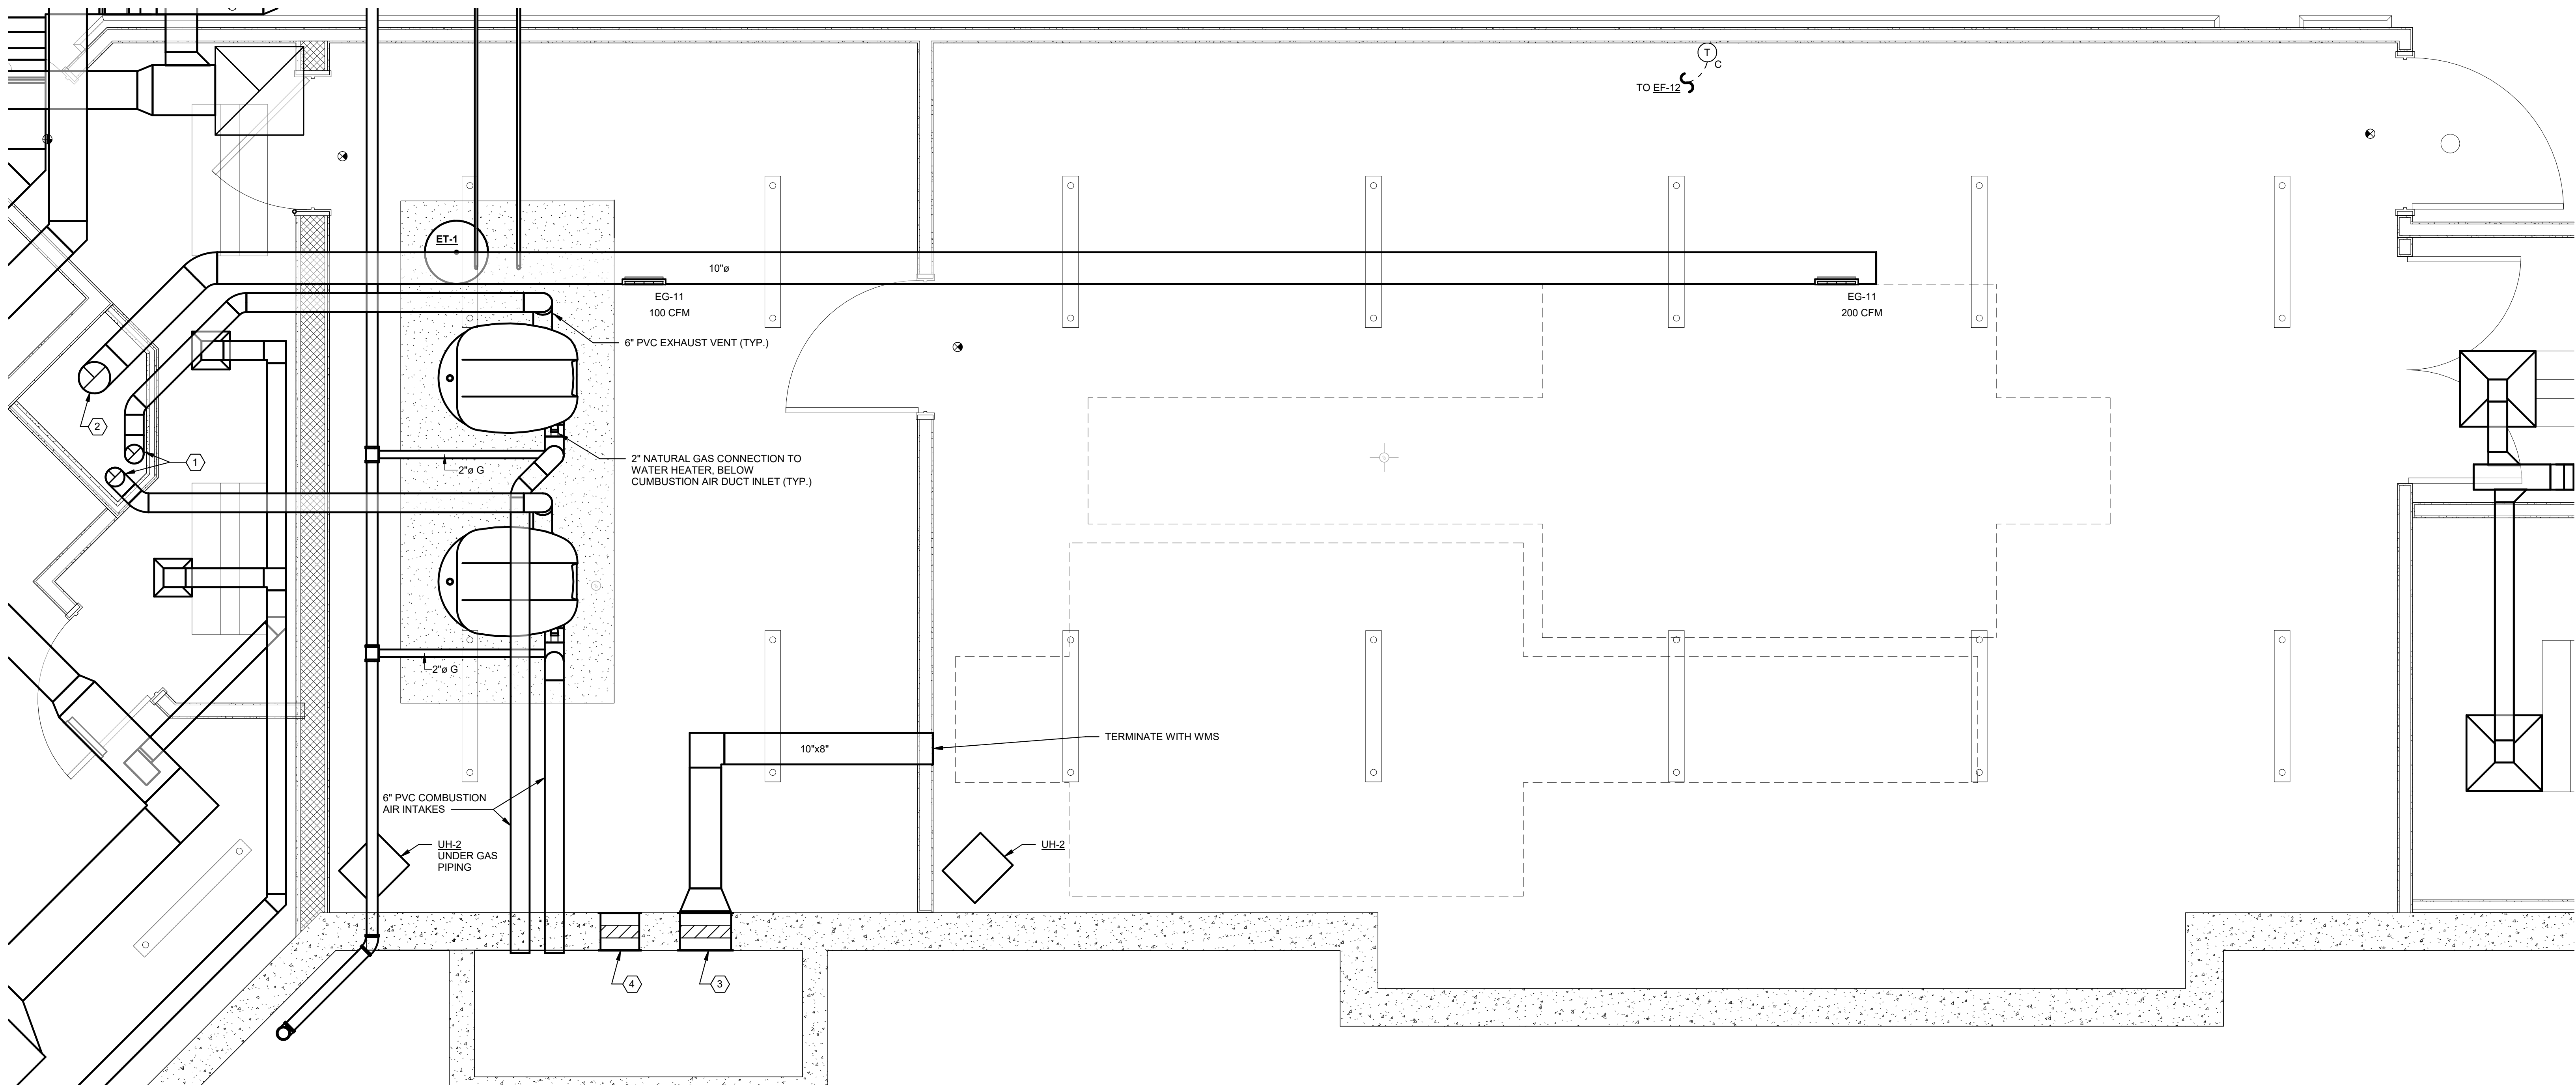


1 HVAC WATER HEATER & MECHANICAL ROOM ENLARGED PLAN

SCALE: 1/2" = 1'-0"

- KEYED NOTES:**

- ① 6" Ø VENTS FROM HOT WATER HEATERS TO BE ROUTED THROUGH CHASE TO TERMINATION CAP ON ROOF. TRANSITION FROM PVC TO HEATBATH SAF-T (AL29-4C) BEFORE VENTS ENTER CHASE.
- ② 10" Ø EXHAUST DUCT TO BE ROUTED THROUGH CHASE TO EF-12 ON ROOF.
- ③ 18"x16" OUTDOOR AIR INTAKE LOUVER WITH MOTORIZED DAMPER FOR MECHANICAL ROOM VENTILATION (L-1). INTERLOCK WITH EF-12 ON ROOF.
- ④ 12"x12" OUTDOOR AIR INTAKE LOUVER WITH MOTORIZED DAMPER FOR WATER HEATER ROOM VENTILATION (L-2). INTERLOCK WITH EF-12 ON ROOF.

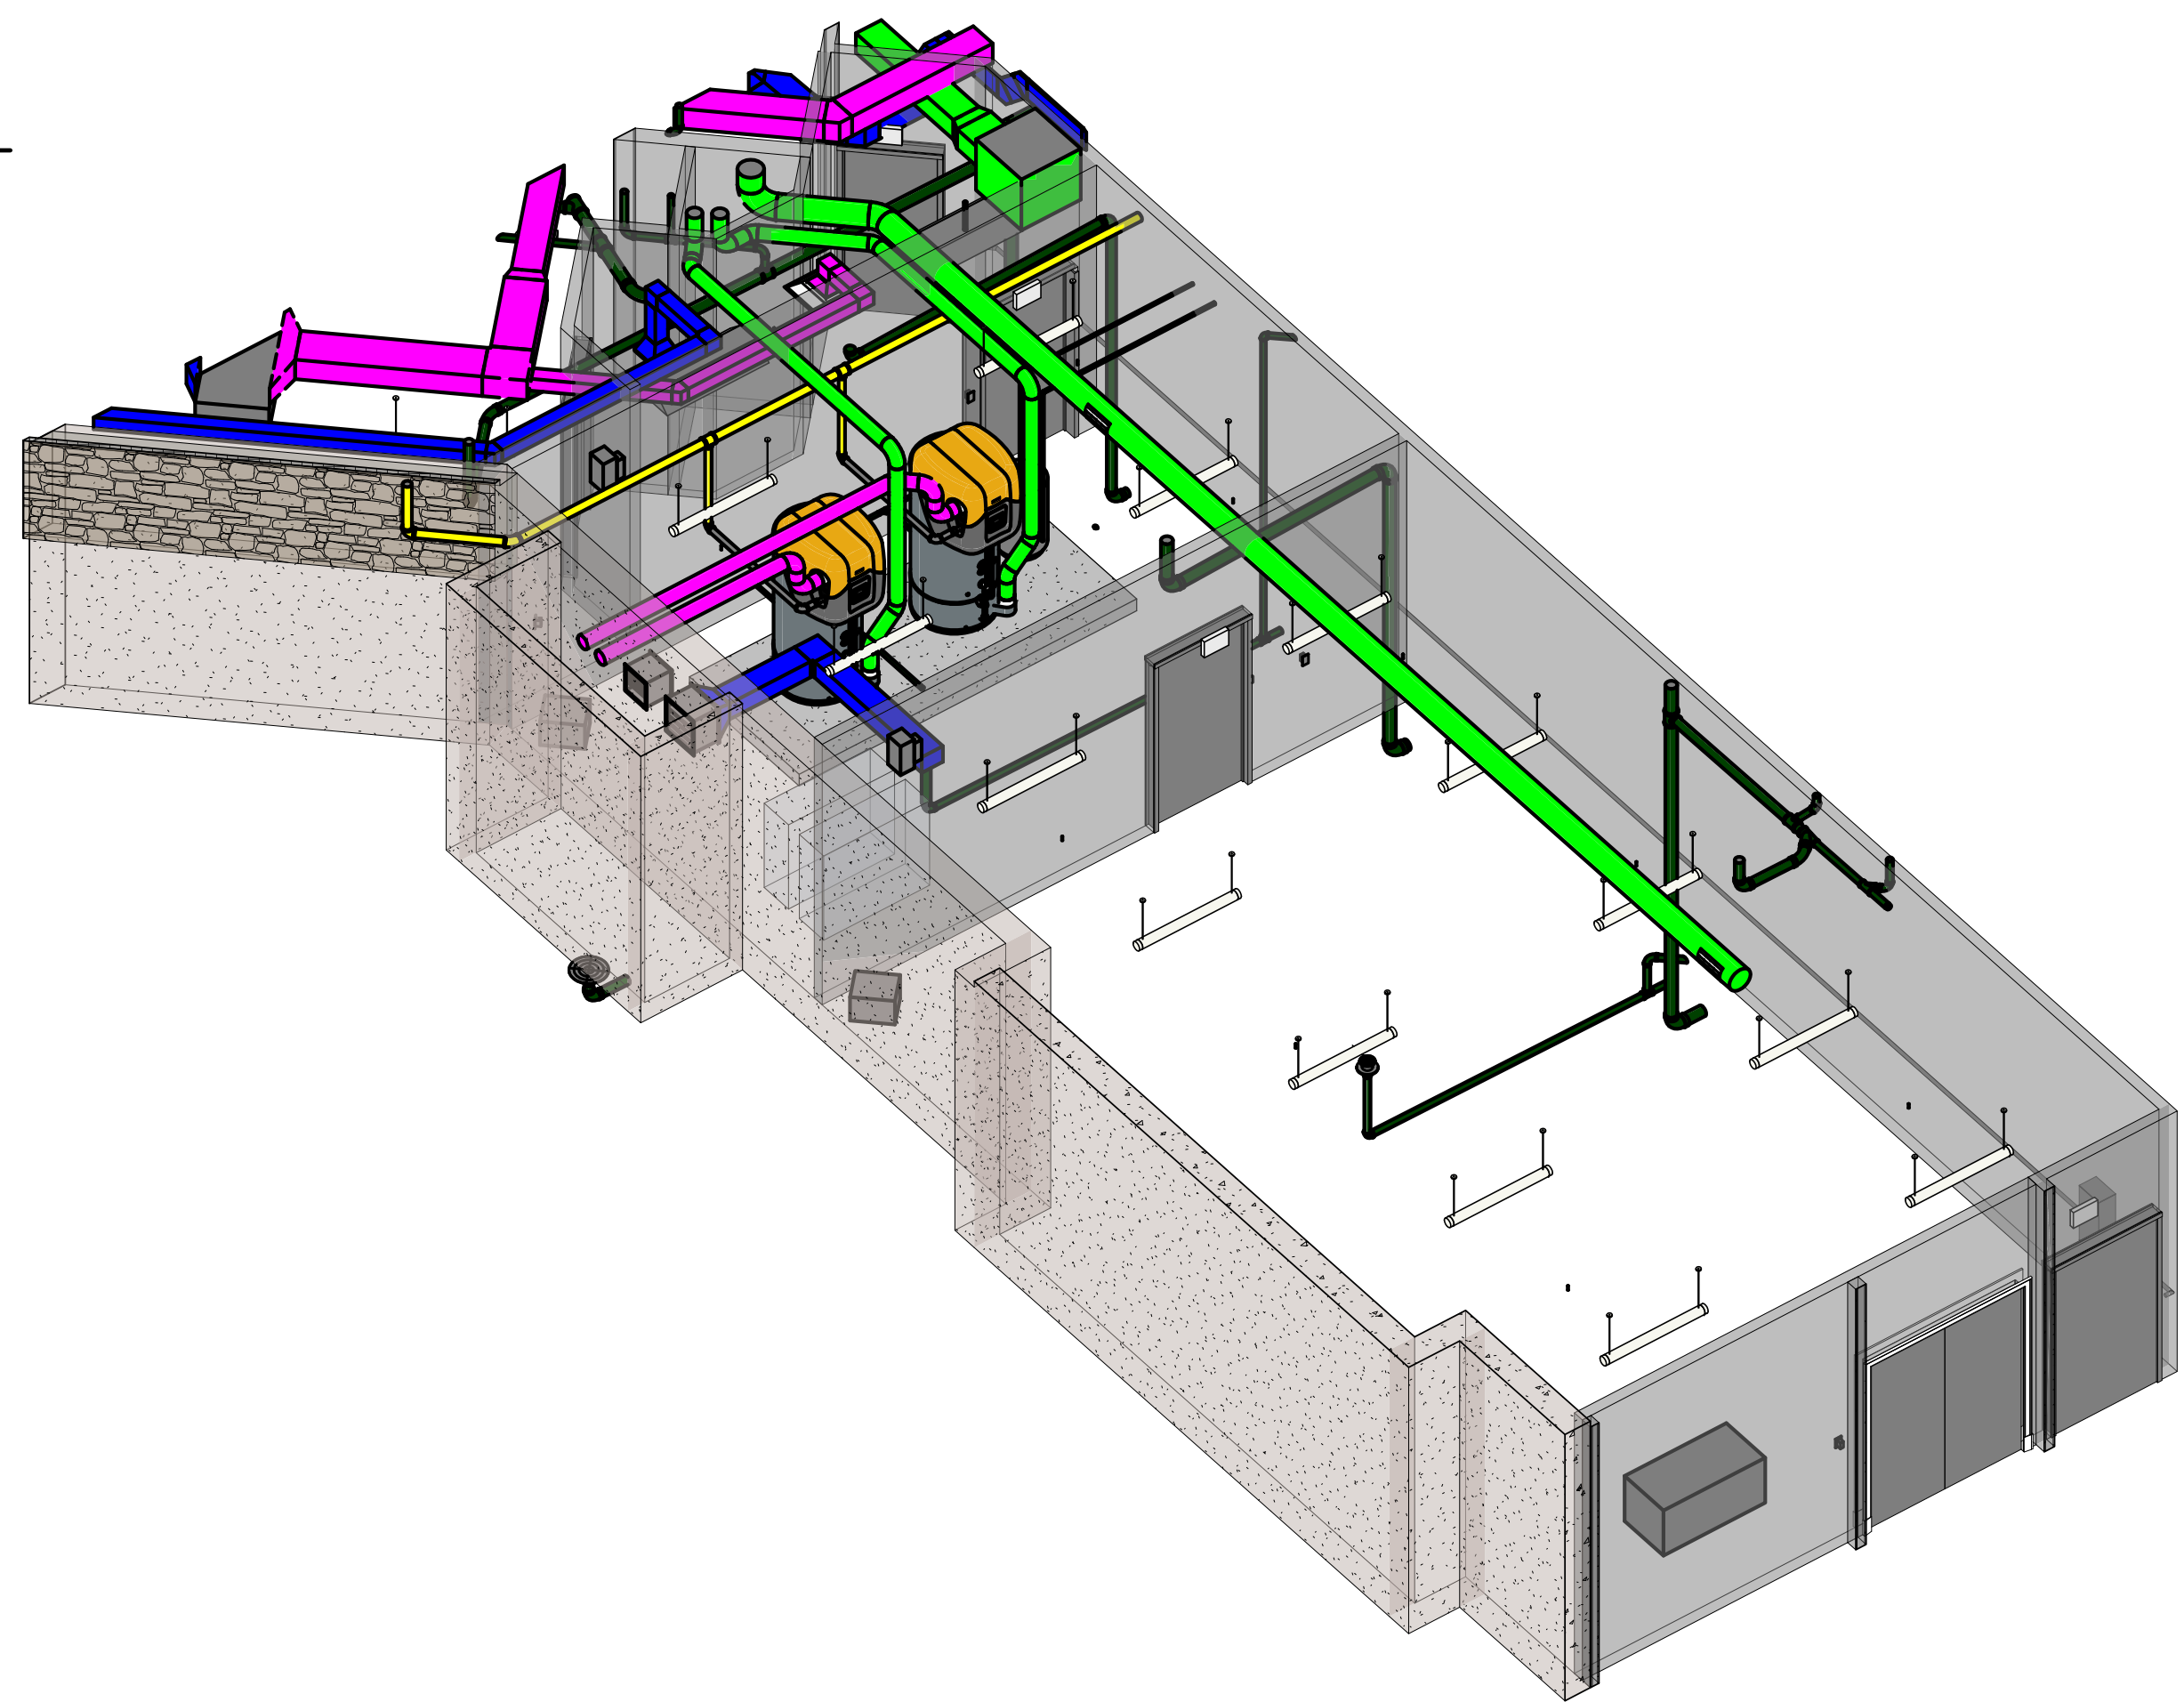

3 CHILLER & BOILER ROOM 3D VIEW

SCALE:

CLIENT

**Montebello Realty
GP LLC**

**Montebello Crossing,
250 Lafayette Avenue
(Route 59)
Village of Montebello
New York**


CONTRACT

STATUS **FOR CONSTRUCTION**

SHEET TITLE

**HVAC ROOF PLAN -
AREA A**

DRAWING No.	SHEET No.
H4.1A	OF

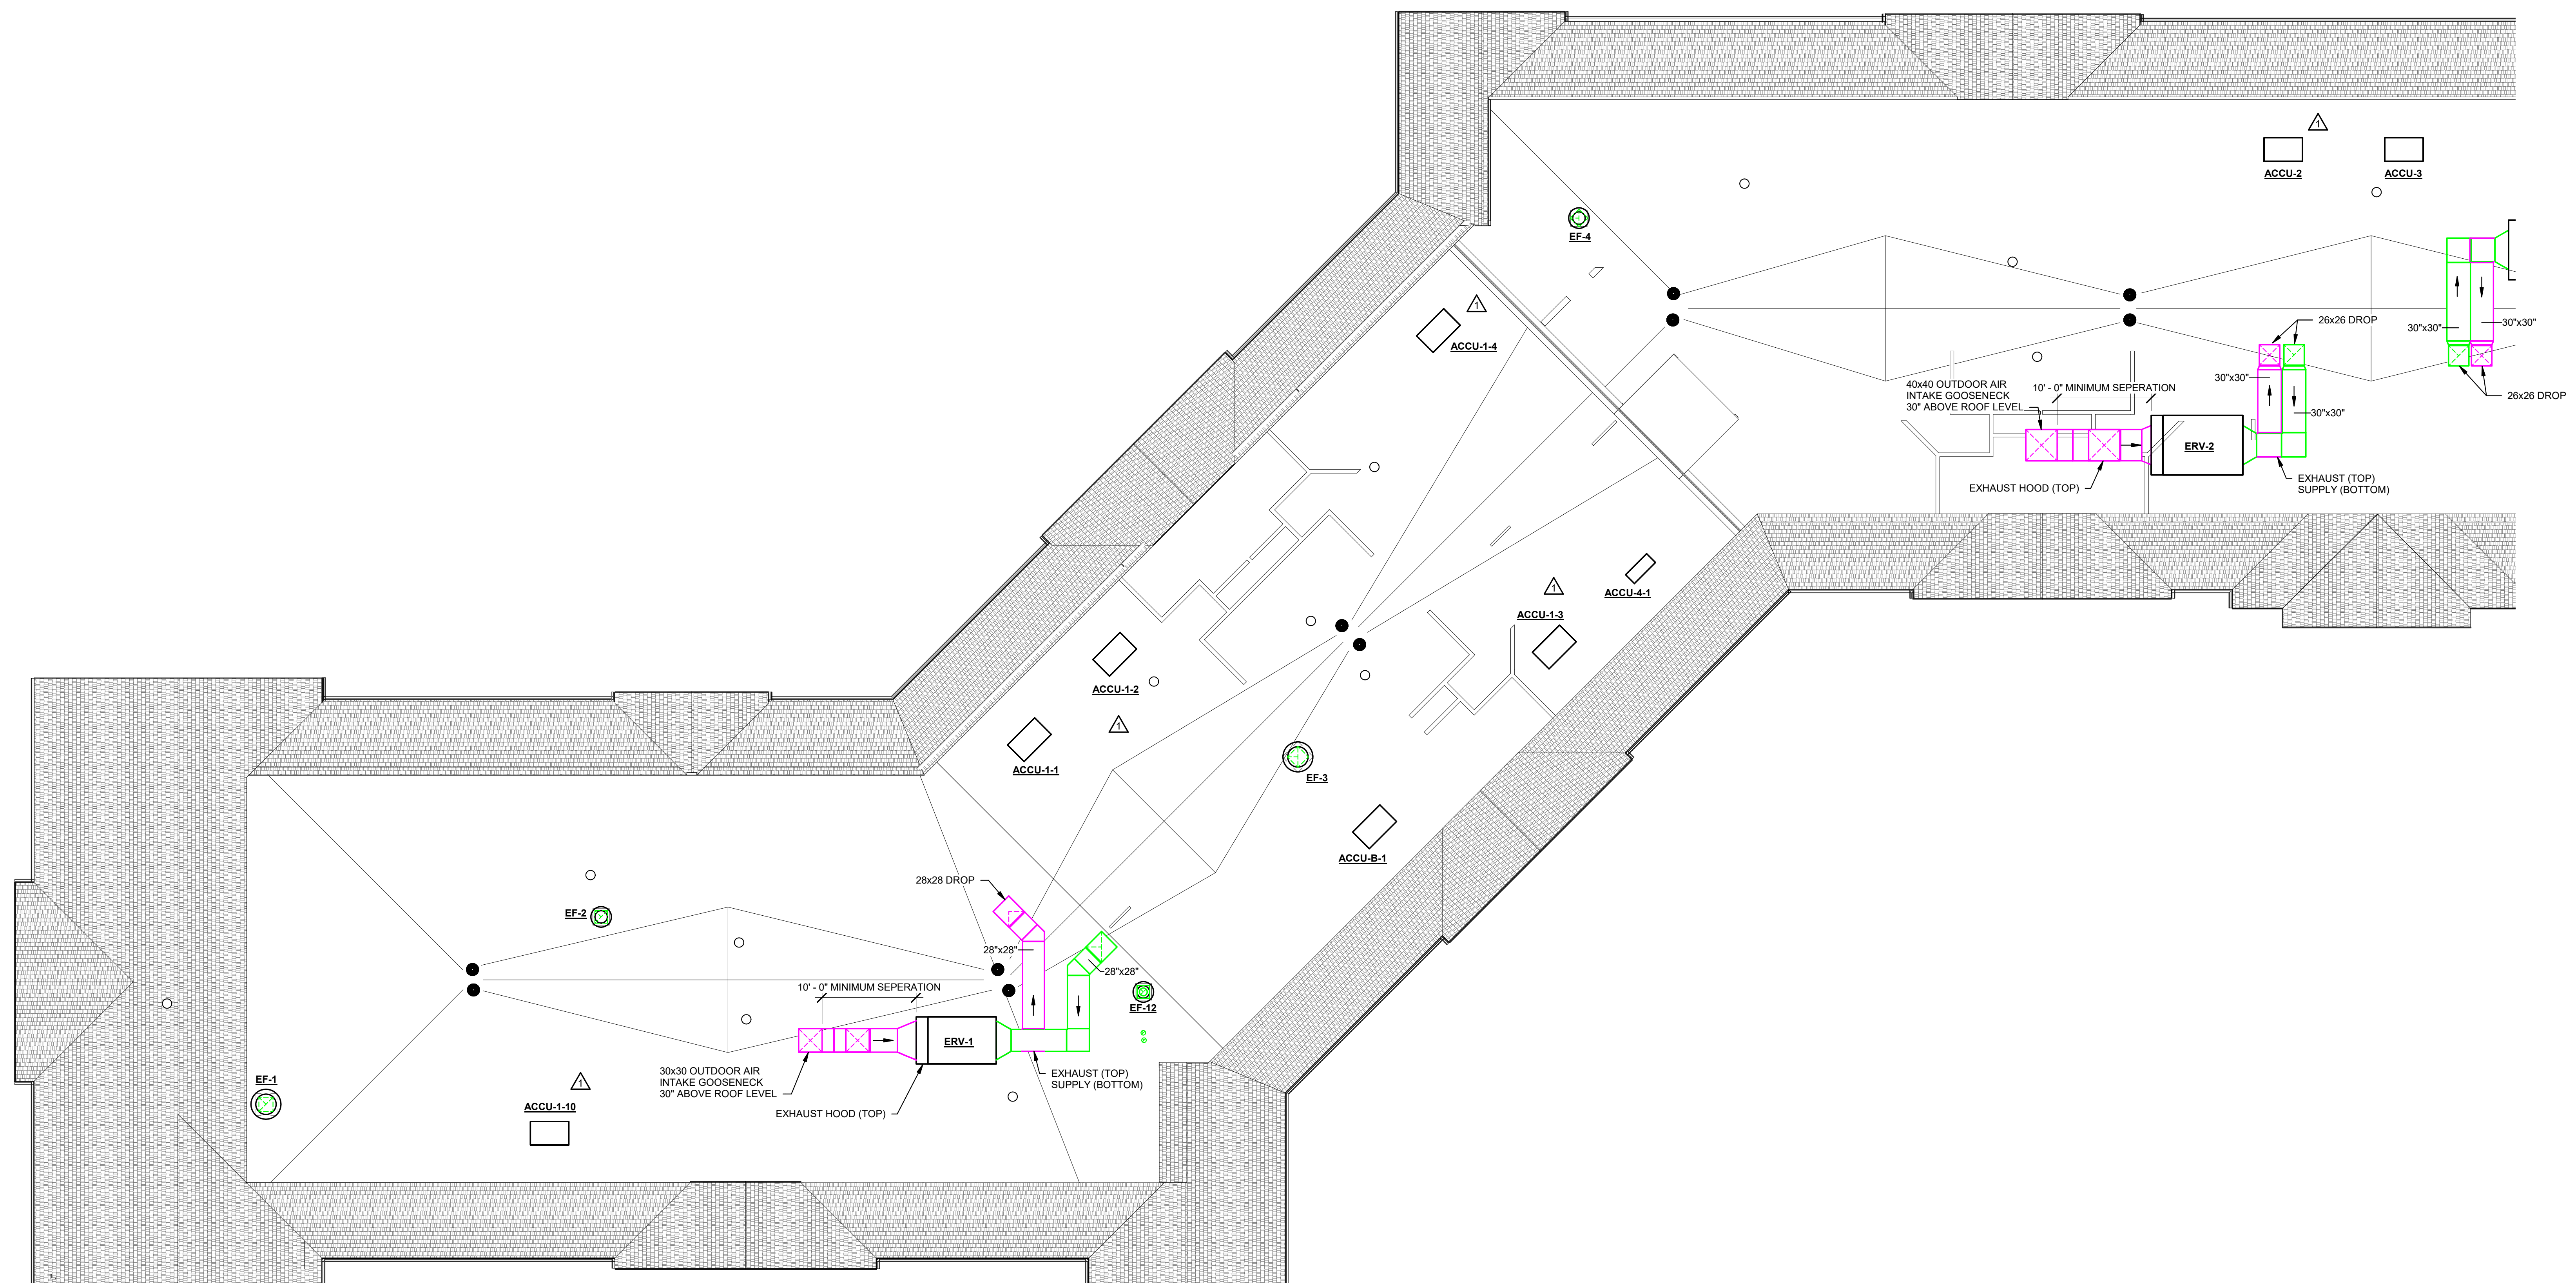

1 HVAC ROOF PLAN - PART A
SCALE: 1/8" = 1'-0"

[illegible]

"ALL INFORMATION CONTAINED HEREIN IS UNCLASSIFIED EXCEPT WHERE SHOWN OTHERWISE"			
DESIGNED BY: PMC	DRAWN BY: SRB	CHECKED BY: EDF	REVIEWED BY: 0
PROJECT NO: FILB 1501		DATE: 11/15/19	SCALE: AS SHOWN


**Braemar at Montebello Assisted
Living Residence**

CONTRACT

SHEET TITLE

**HVAC ROOF PLAN -
AREA B**

DRAWING No. H4.1B	SHEET No. OF
--	--

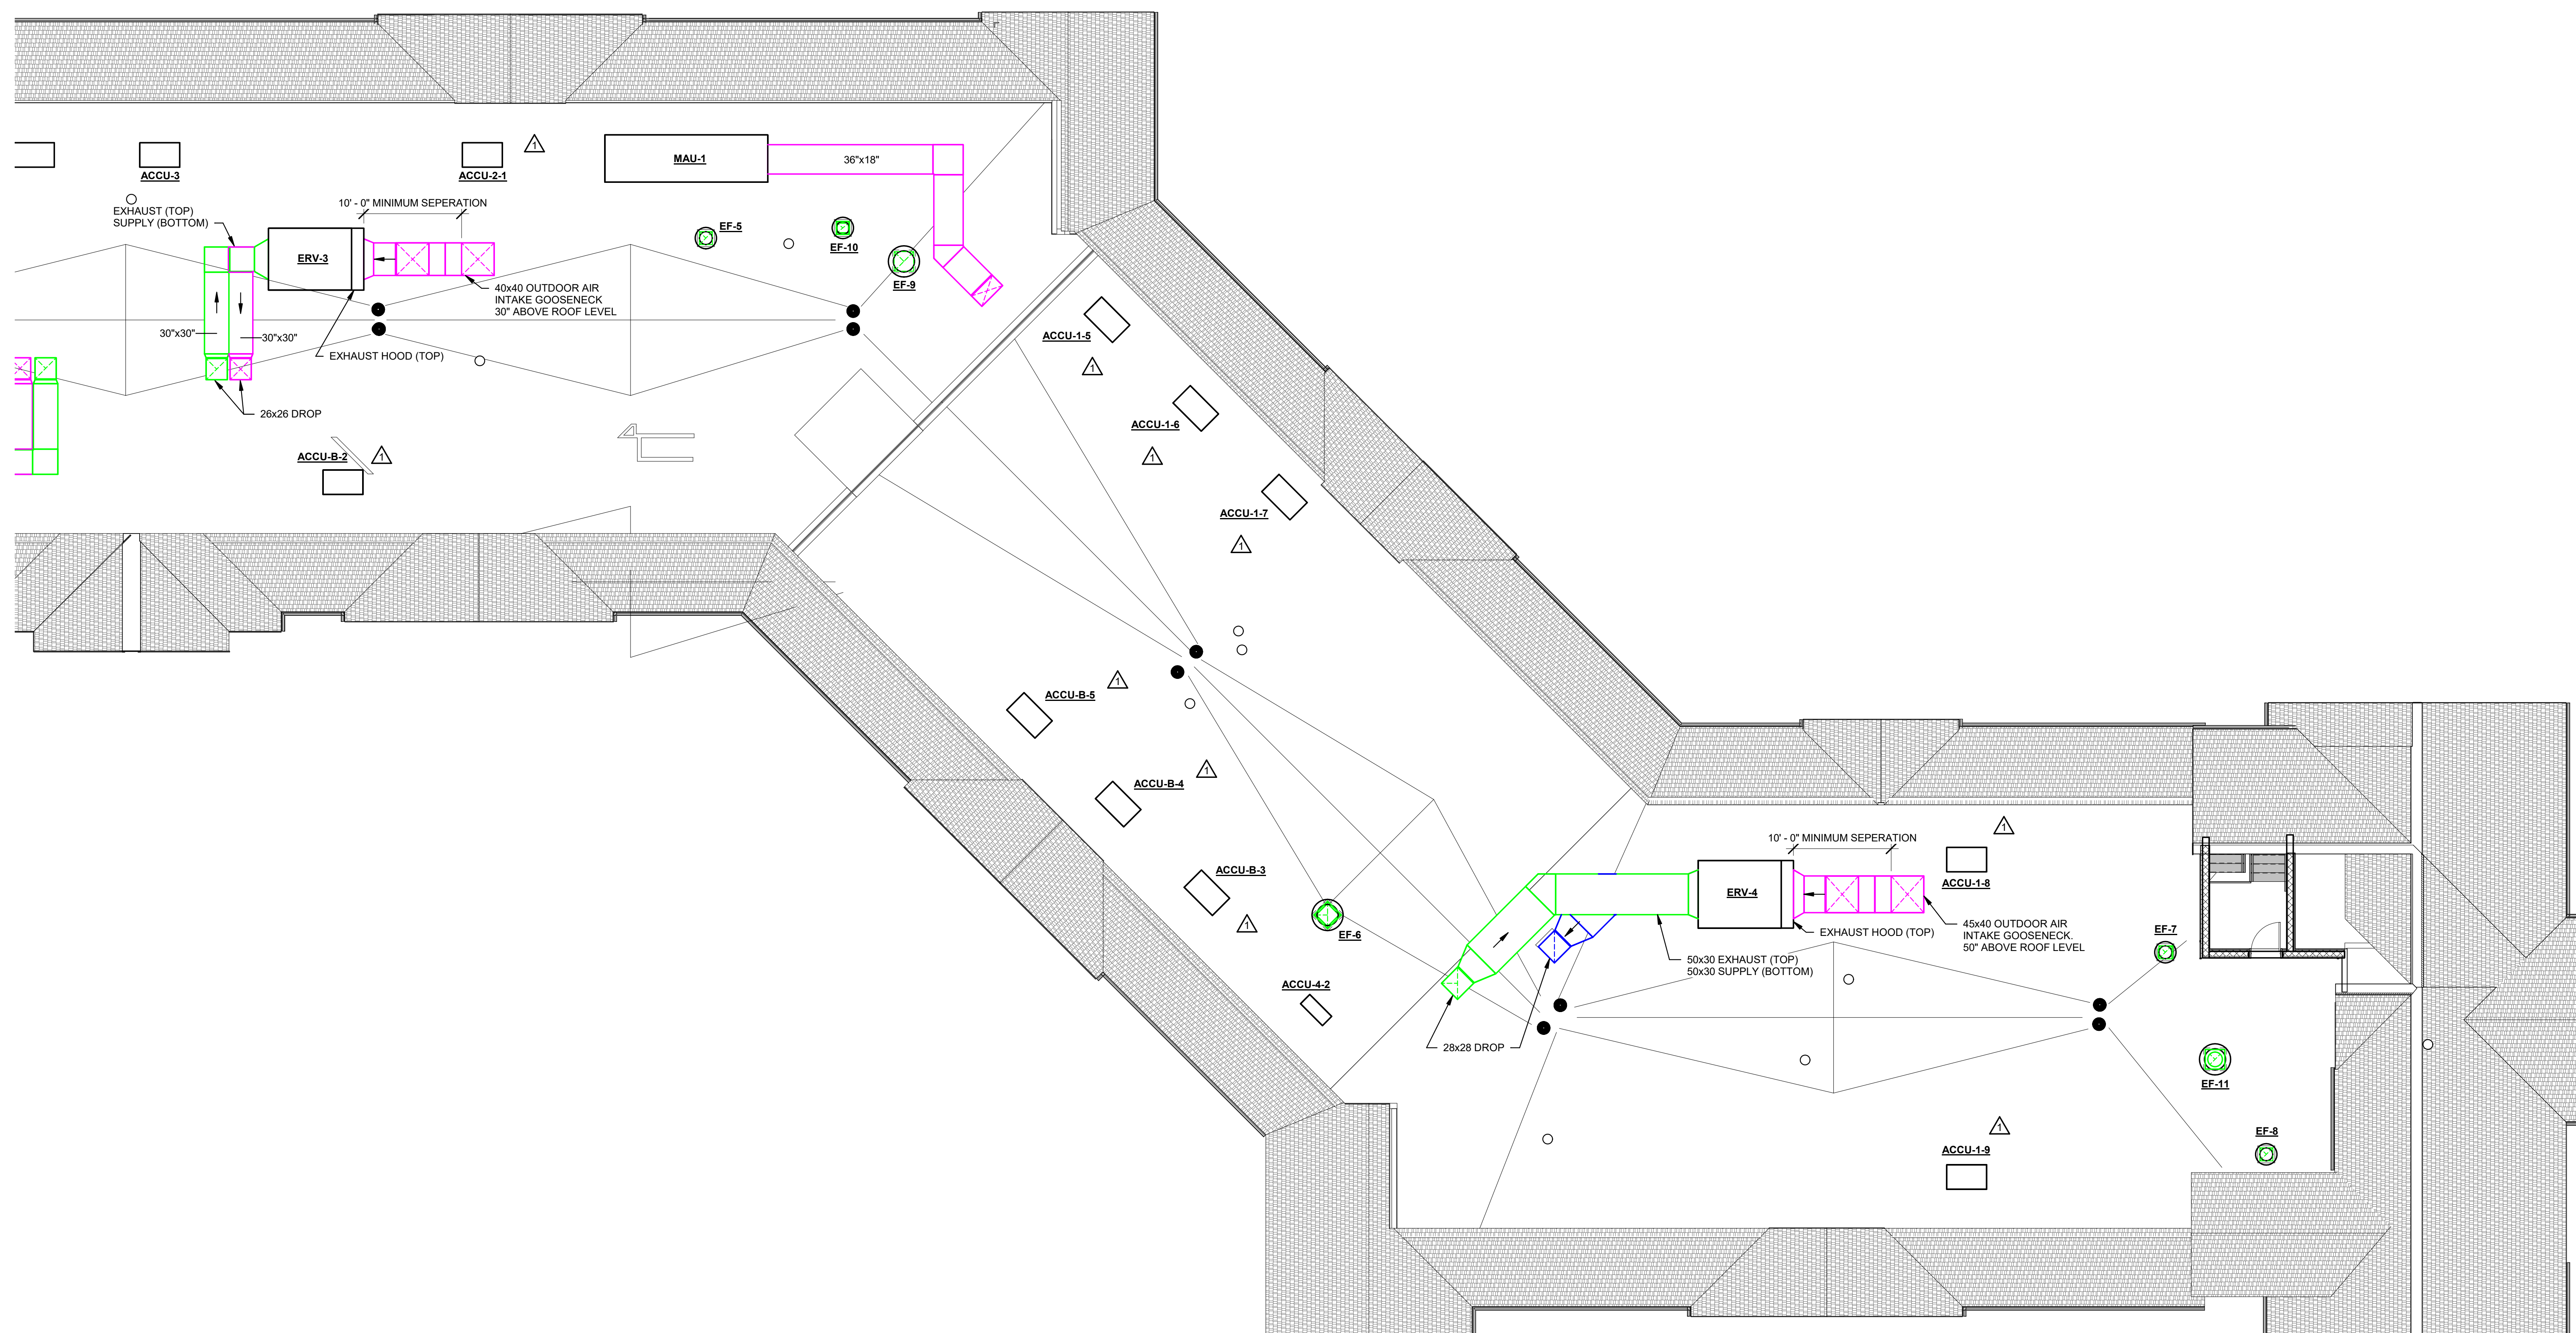

1 HVAC ROOF PLAN - PART B
SCALE: 1/8" = 1'-0"

[illegible]

"ALTERATION OF THIS DOCUMENT IS LEGAL BY A LICENSED PROFESSIONAL IS LEGAL."			
DESIGNED BY: PMC	DRAWN BY: SRB	CHECKED BY: EDF	REVIEWED BY: MDF
PROJECT No: FILB 1501	DATE: 11/15/19	SCALE: AS SHOWN	

CLIENT
**Montebello Realty
GP LLC**

**Braemar at Montebello Assisted
Living Residence**

**Montebello Crossing,
250 Lafayette Avenue
(Route 59)
Village of Montebello
New York**

CONTRACT

STATUS	FOR CONSTRUCTION
--------	------------------

SHEET TITLE


HVAC:
DETAILS

DRAWING No. H7.1	SHEET No. OF
---	--

CONTROL LEGEND	
SYMBOL	DESCRIPTION
	RELAY
	DUCT TEMPERATURE SENSOR
	DUCT HUMIDITY SENSOR
	CURRENT SENSOR
	MOTOR STARTER
	DIFFERENTIAL PRESSURE SENSOR/SWITCH
	DUCT SMOKE DETECTOR
	MOTORIZED DAMPER
	FREEZE STAT
DA-T	DISCHARGE AIR SENSOR
SF-S	SUPPLY FAN STATUS
SF-G	SUPPLY FAN CURRENT SENSOR
	CO ₂ SENSOR FOR AIR HANDLERS SERVING MULTIPURPOSE ROOMS ONLY

KEYED NOTES:

- ① CONTROL WIRING PROVIDED AND INSTALLED BY KLIMA NY. ⚠
- WORK DONE BY ELECTRICAL CONTRACTOR (E.C.)
- REFER TO SPECIFICATIONS FOR CONTROL POINTS AND SEQUENCE OF OPERATION.
- CONTROL WIRING BY HVAC CONTRACTOR

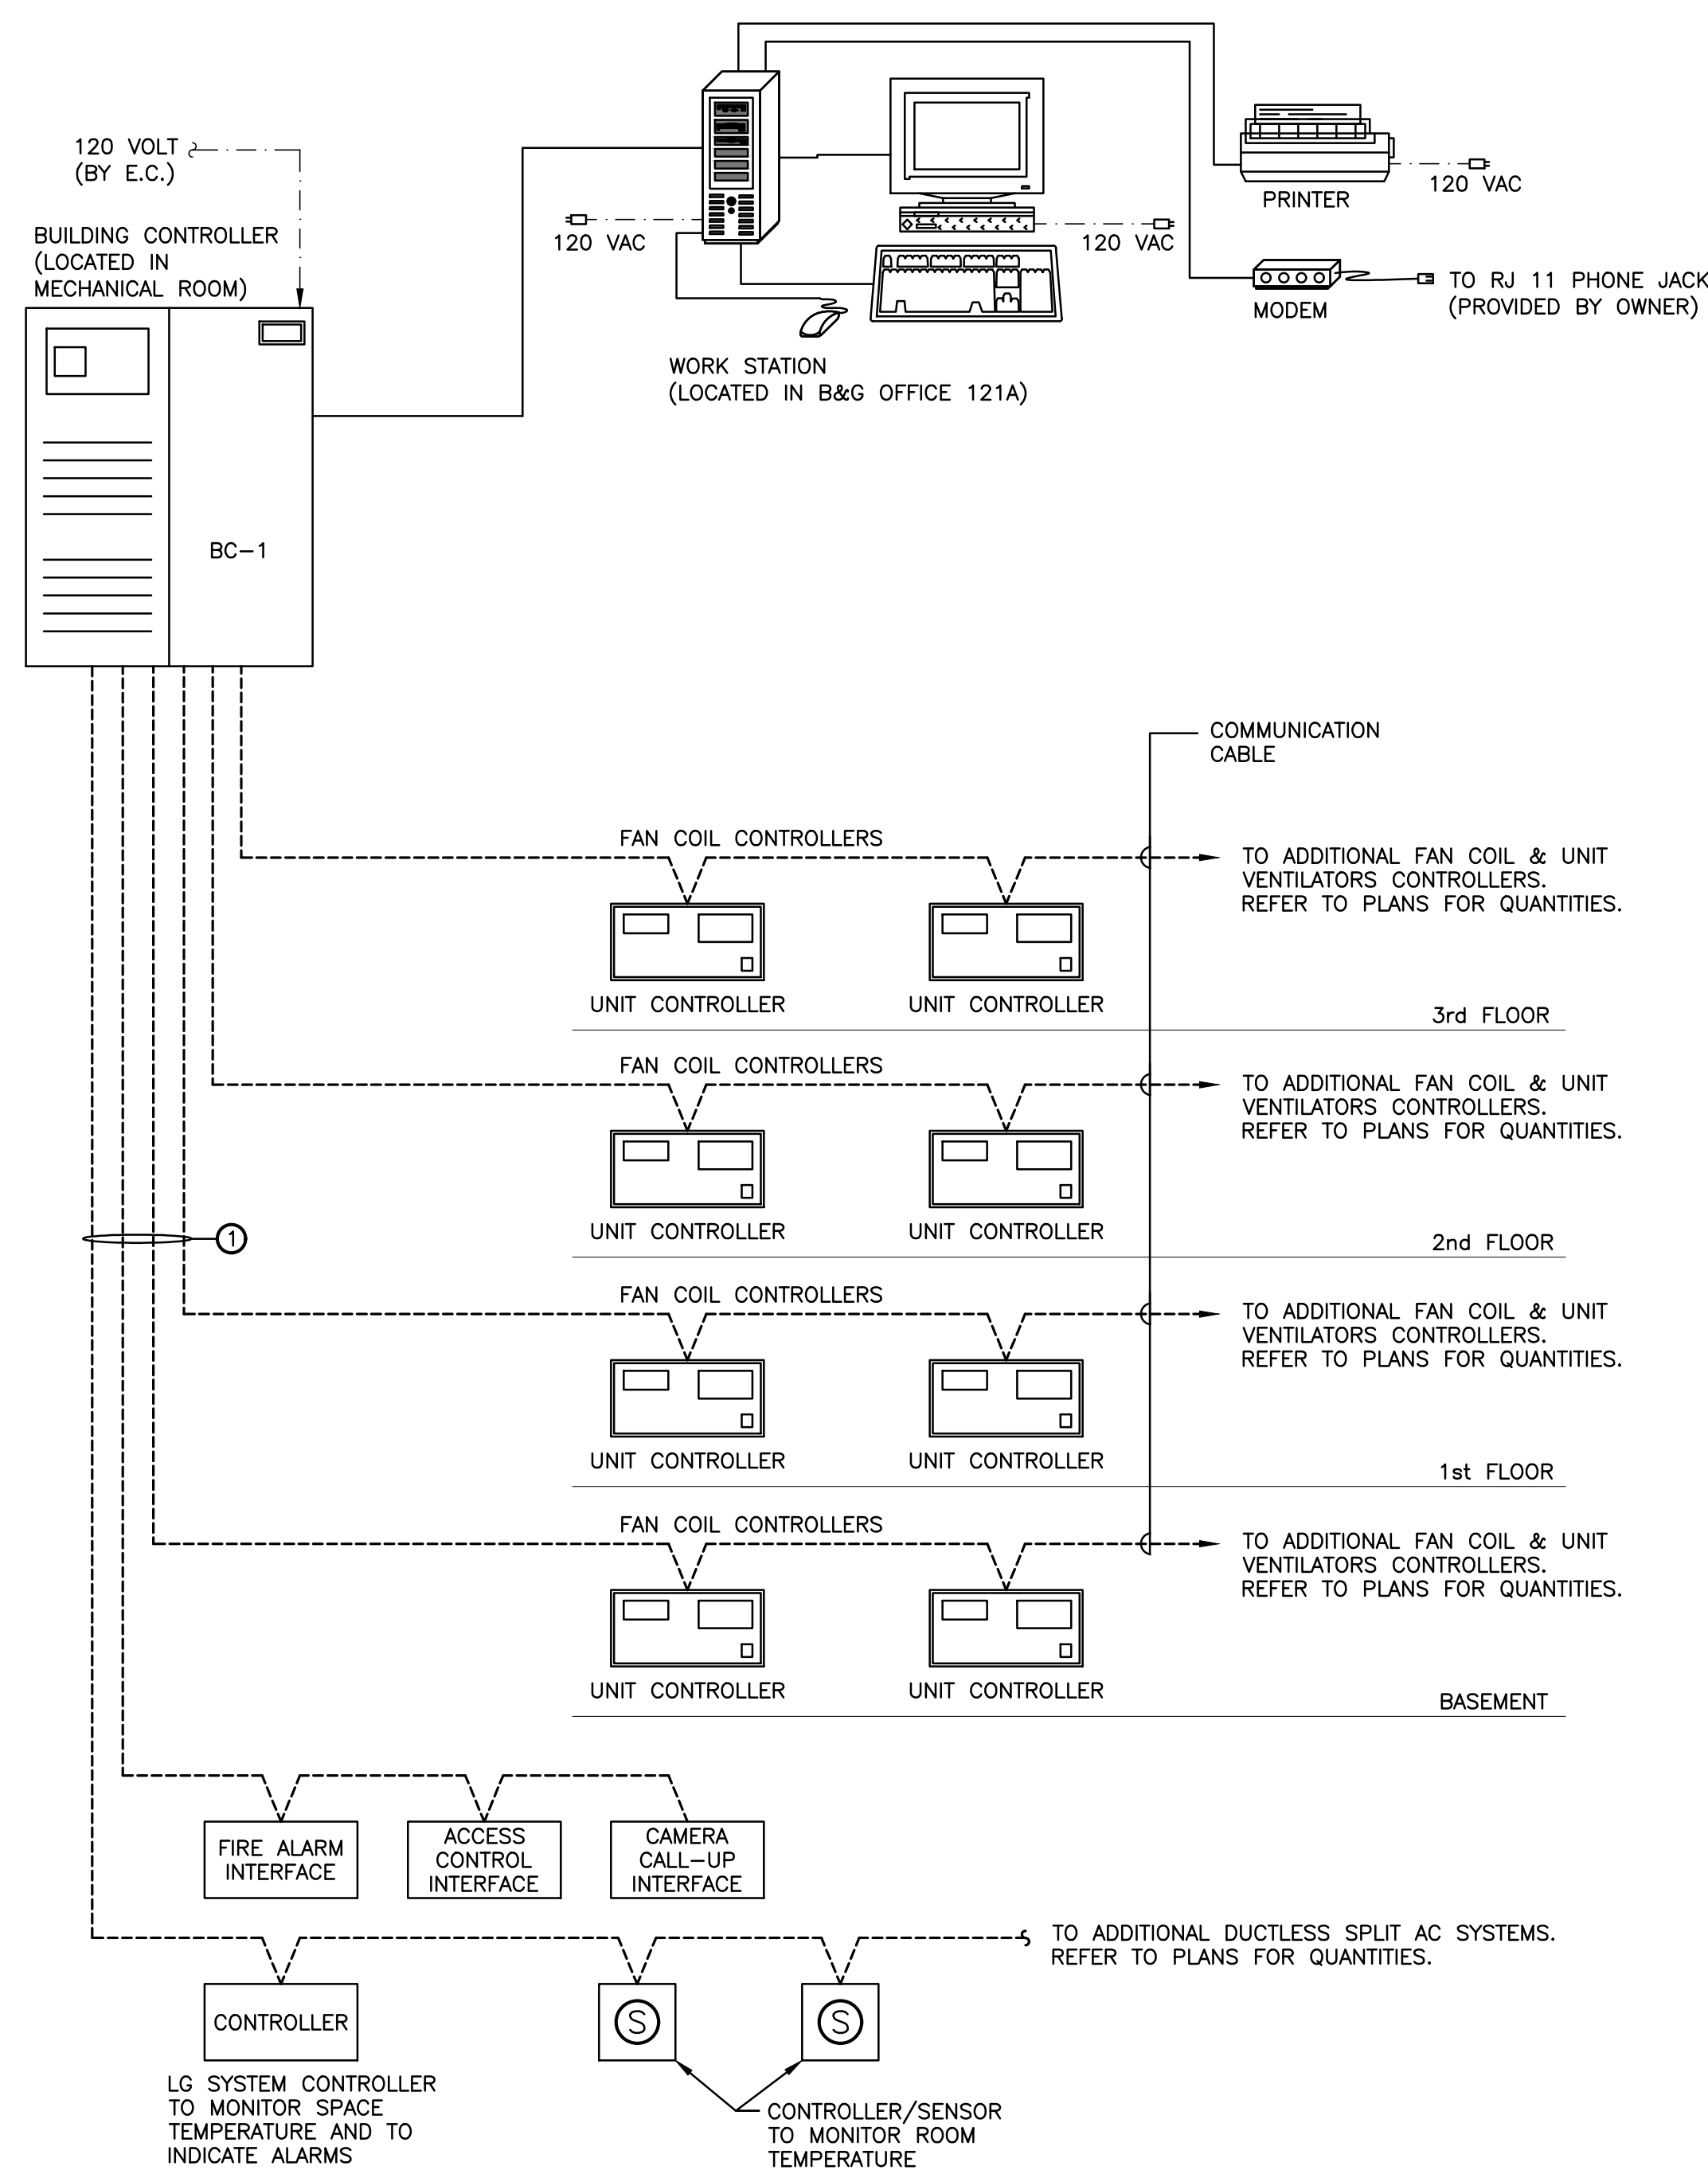

1 SYSTEM ARCHITECTURE ONE-LINE DIAGRAM
N.T.S.

N.T.S

[illegible]

ALTERATION OF THIS DOCUMENT EXCEPT BY A LICENSED PROFESSIONAL IS ILLEGAL.			
DESIGNED BY: PMC	DRAWN BY: SRB	CHECKED BY: EDF	REVIEWED BY: MDF
PROJECT No: FILB 1501		DATE: 11/15/19	SCALE: AS SHOWN

CLIENT
**Montebello Realty
GP LLC**

**Braemar at Montebello Assisted
Living Residence**

**Montebello Crossing,
250 Lafayette Avenue
(Route 59)
Village of Montebello
New York**

CONTRACT


STATUS	FOR CONSTRUCTION
--------	------------------

SHEET TITLE


HVAC: DETAILS

DRAWING No.	SHEET No.
-------------	-----------

H7.2

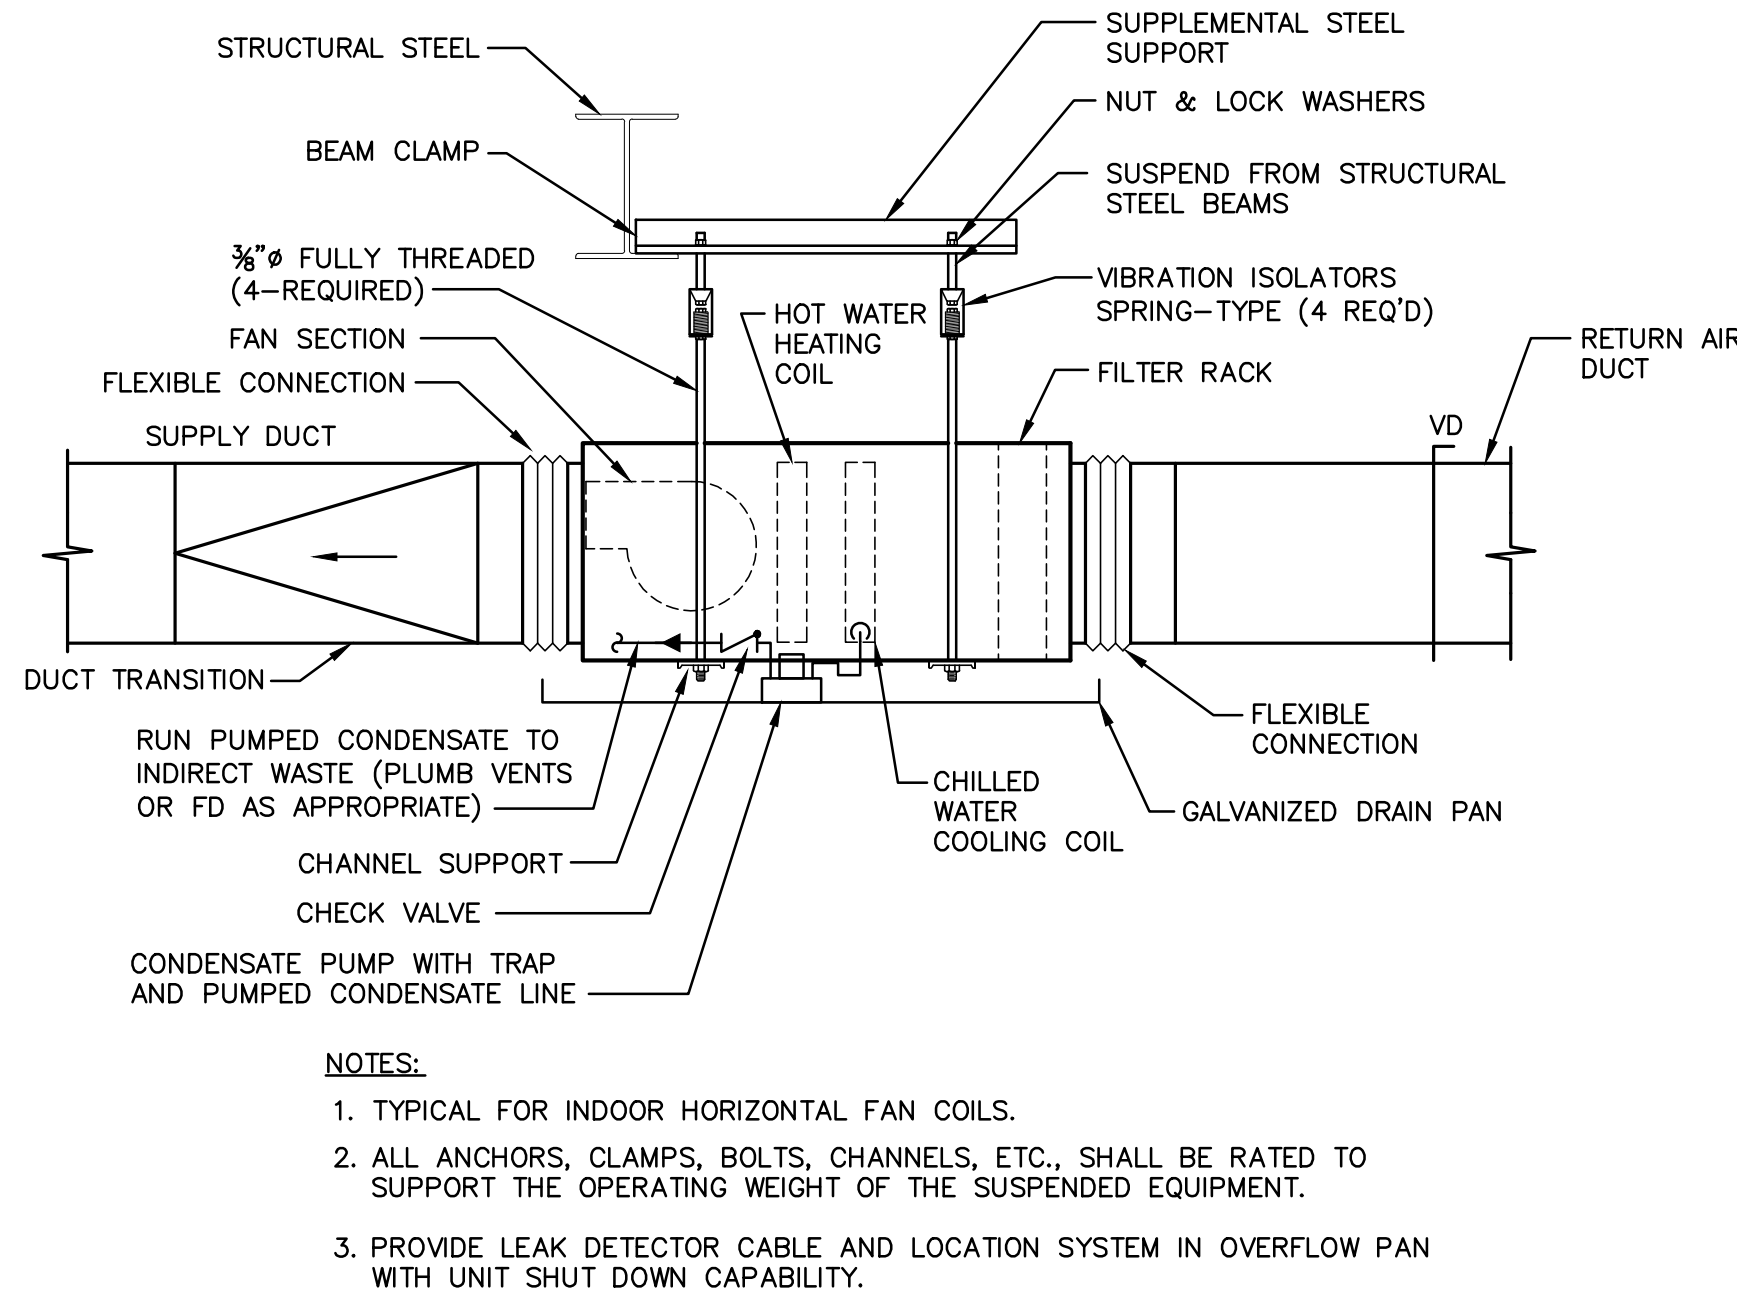

1 HORIZONTAL FAN COIL UNIT DETAIL
N.T.S.

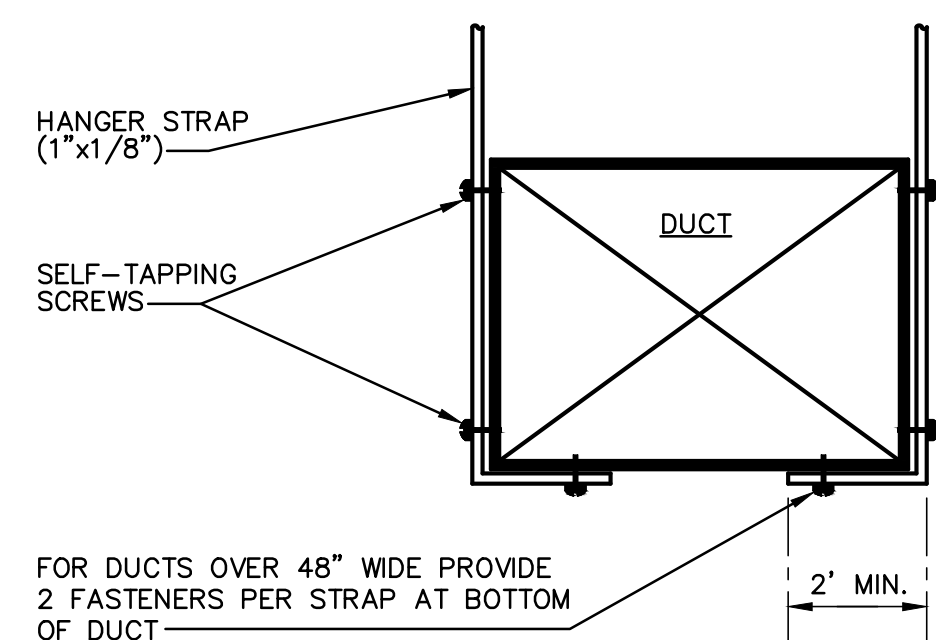


NOTES:


1. PROVIDE BRACING TO LIMIT THE AMPLITUDE OF WALL VIBRATION
AND WALL DEFLECTION TO SPECIFIED MAXIMUMS.

DUCT SIZE (SQ. FT.)	HANGER SIZE (IN.XGA.)	MAX. SPACING (FT.)
<2	1"x20 GA.	8
2<x≤4	1"x20 GA.	8
4<x≤10	1"x20 GA.	6
10<x	1"x18 GA.	4


3. ALL INTERIOR BLACK IRON EXHAUST DUCTWORK SHALL BE SUPPORTED AT 6FT. INTERVALS MIN.

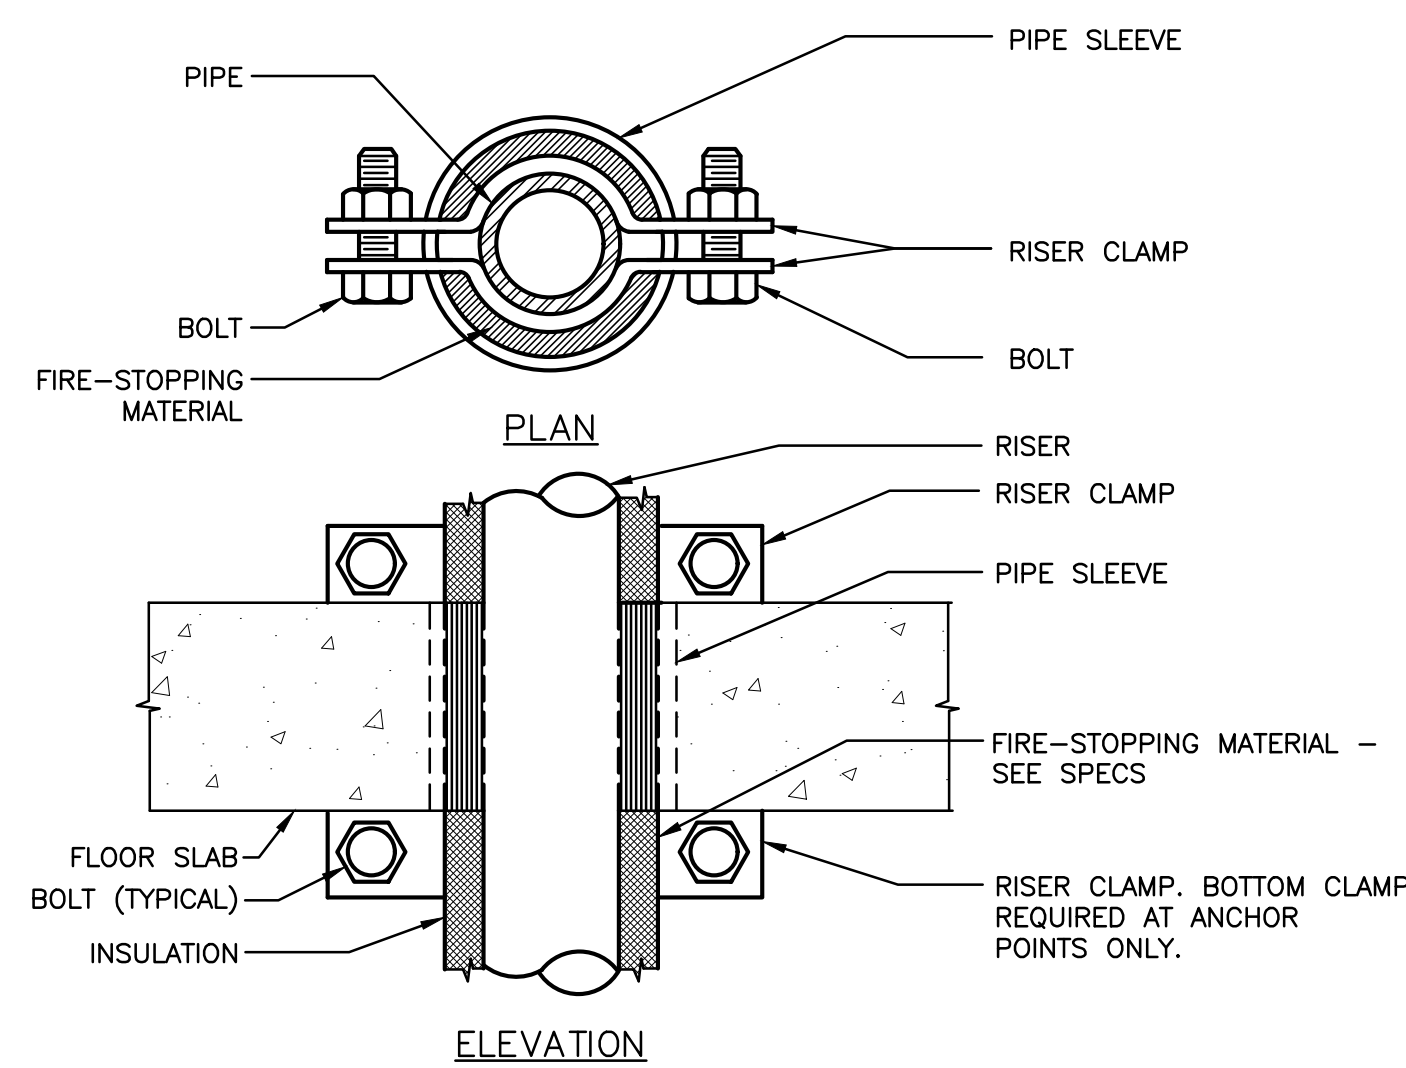


3 SUPPORT/ANCHOR FOR PIPE RISERS
N.T.S.

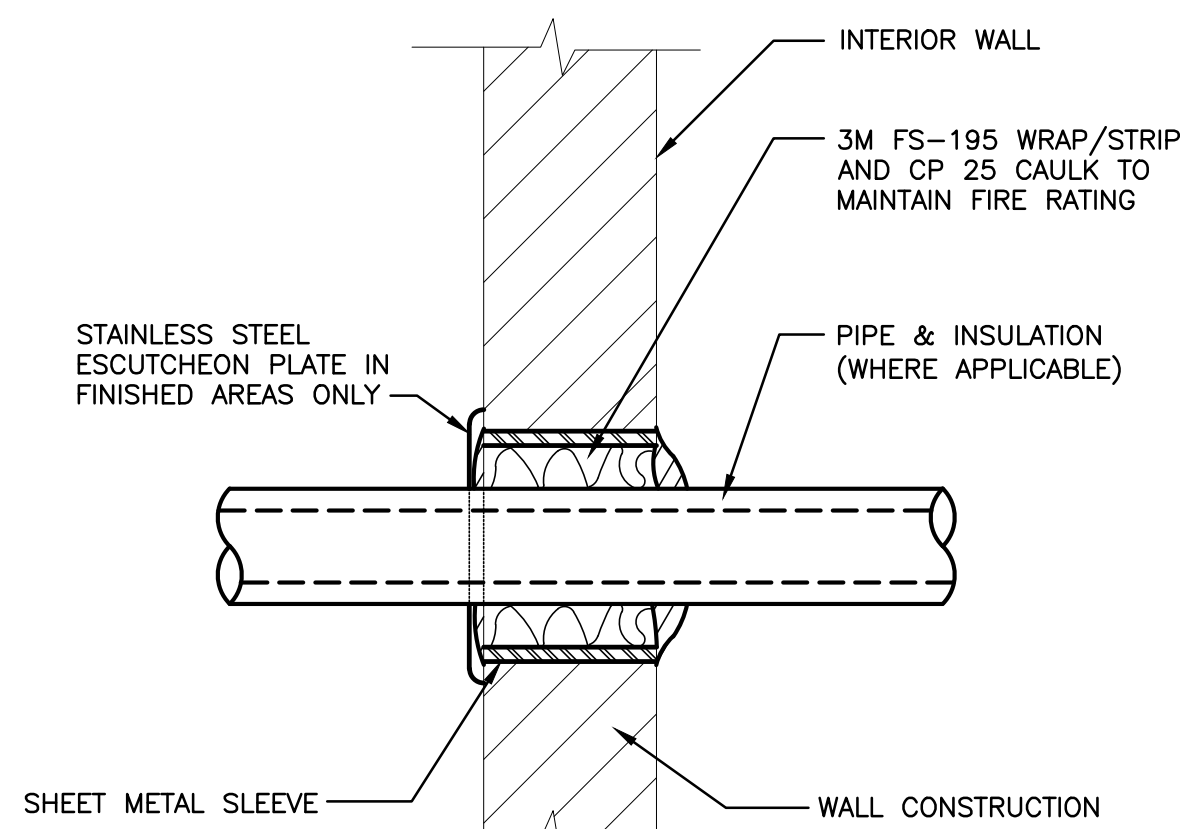


4 **RATED WALL PENETRATION DETAIL**
N.T.S.

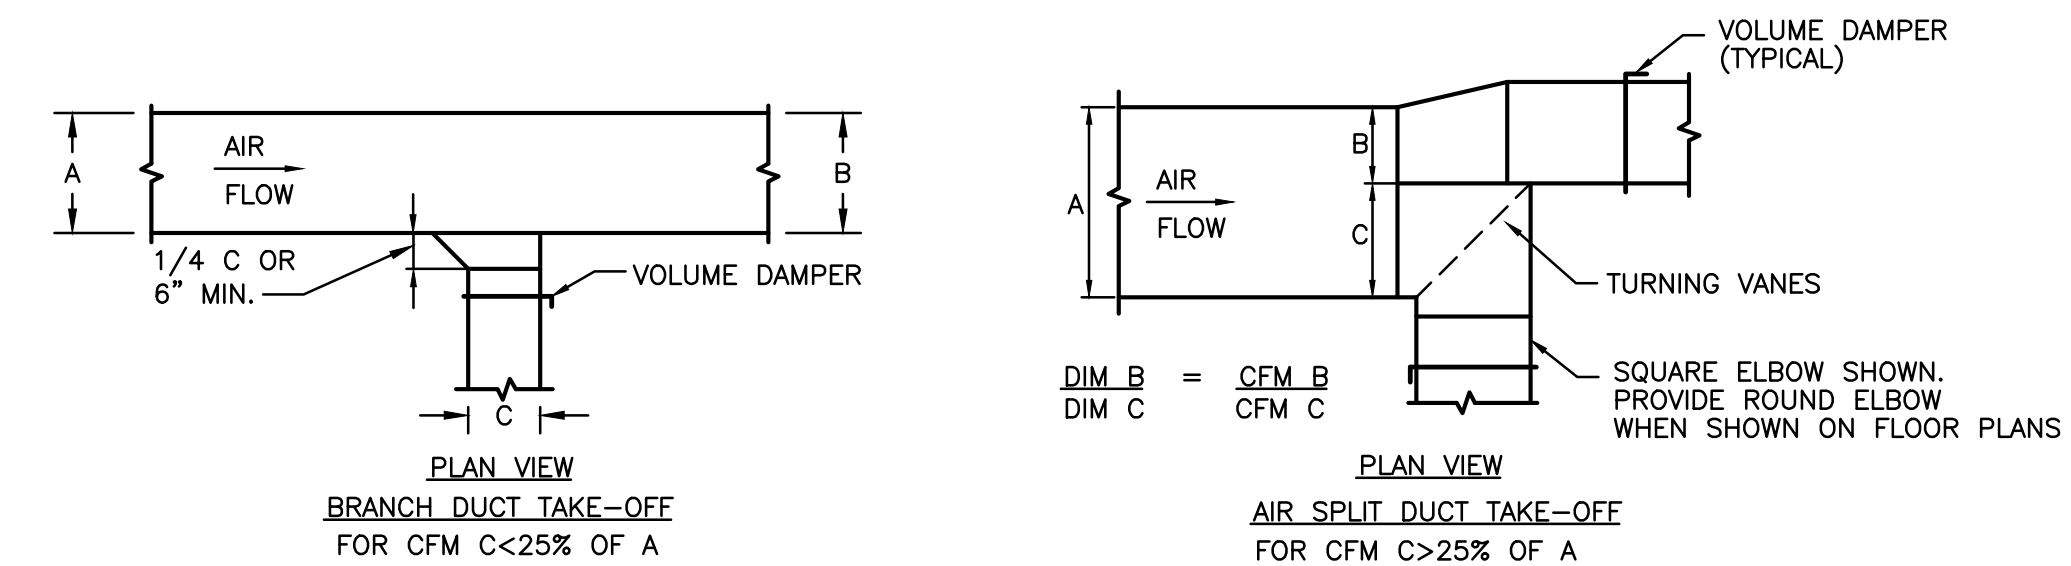

5 SUPPLY DUCTWORK TAKE-OFFS
N.T.S.

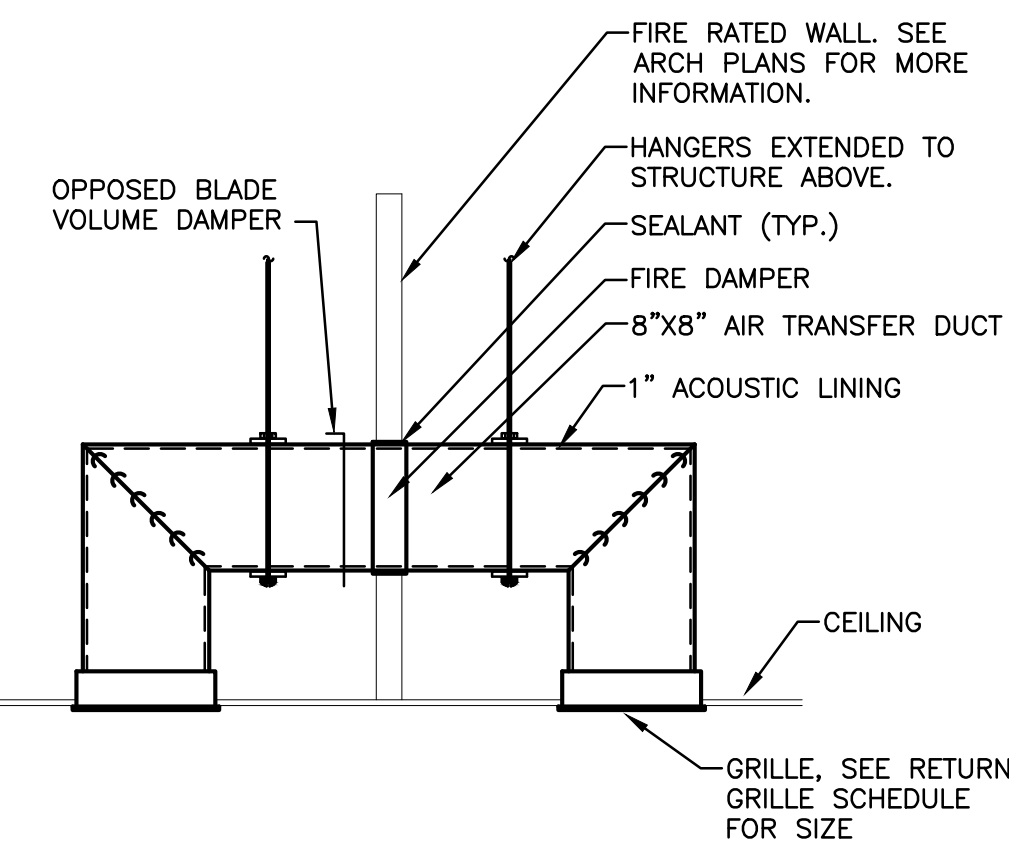


6 AIR TRANSFER DUCT W/ FIRE DAMPER DETAIL
N.T.S.

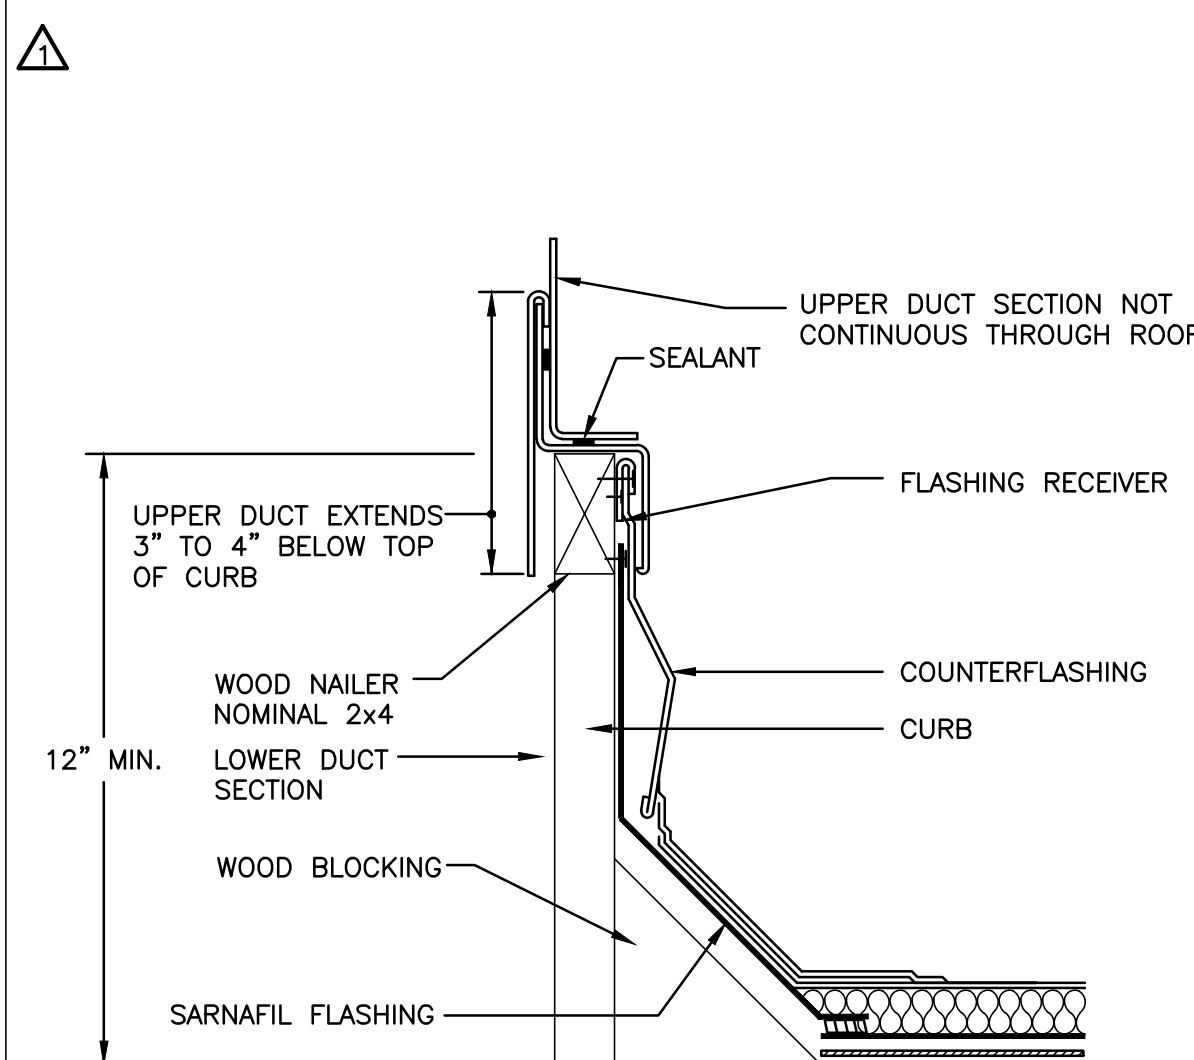


7 DUCT PENETRATION OF ROOF
N.T.S.

- ① GRV. (RELIEF)
- ② PREFABRICATED CURB
- ③ 1'-6"
- ④ FLASHING
- ⑤ ROOFING - REFER TO ARCH. DRAWINGS
- ⑥ GASKET
- ⑦ MOTORIZED DAMPER
- ⑧ FASTEN AS PER MANUFACTURER'S
WRITING RECOMMENDATIONS
- ⑨ GRAVITY RELIEF DAMPER
- ⑩ BIRD SCREEN
- ⑪ LATCH
- ⑫ HINGE
- ⑬ DUCT COLLAR SAME SIZE
AS ROOF OPENING

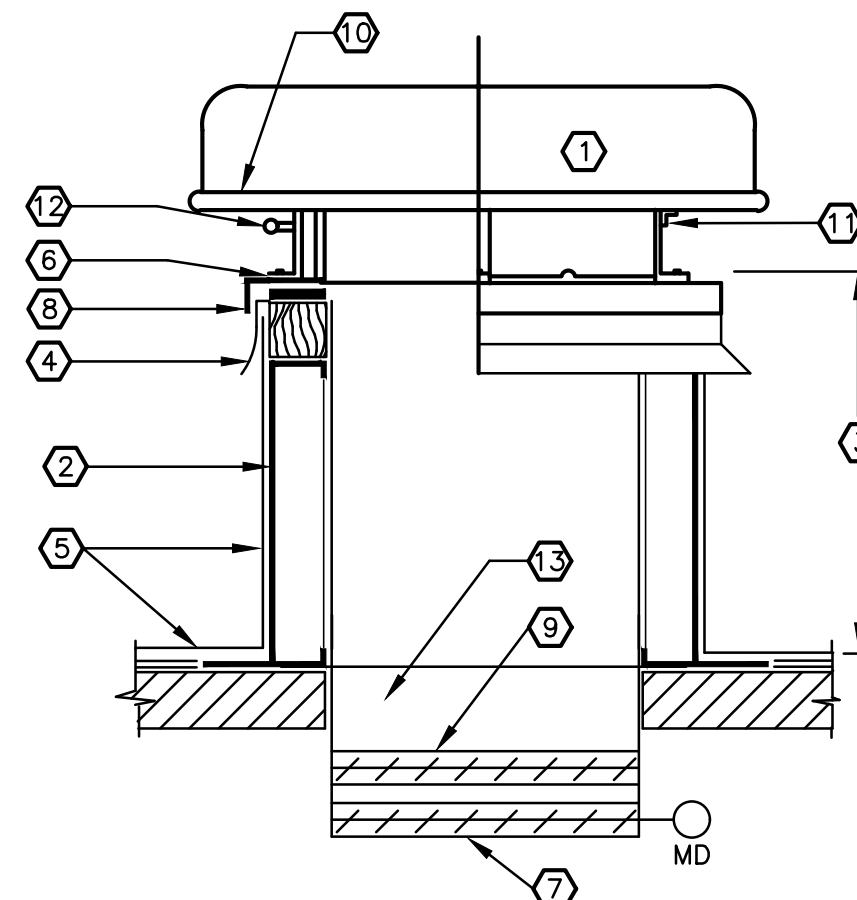


8 GRAVITY ROOF VENT DETAIL
N.T.S.

- ① 1" MINIMUM THICK ELASTOMERIC FIRESTOP SEALANT CAULK. PROVIDE AT TOP AND BOTTOM OF SLEEVE.
- ② FILL ANNULAR SPACE WITH MINERAL WOOL BATTING.
- ③ PROVIDE ELASTOMERIC FIRESTOP SEALANT AT SLEEVE/CONCRETE INTERFACE.
- ④ SECURE SLEEVE TO FLOOR SLAB OR PIP WALL USING ANGLE IRON WELDED TO SLEEVE AND BOLTED TO CONCRETE (TWO MINIMUM).
- ⑤ SUPPORT PIPE USING RISER CLAMP RESTING ON PIPE SLEEVE.

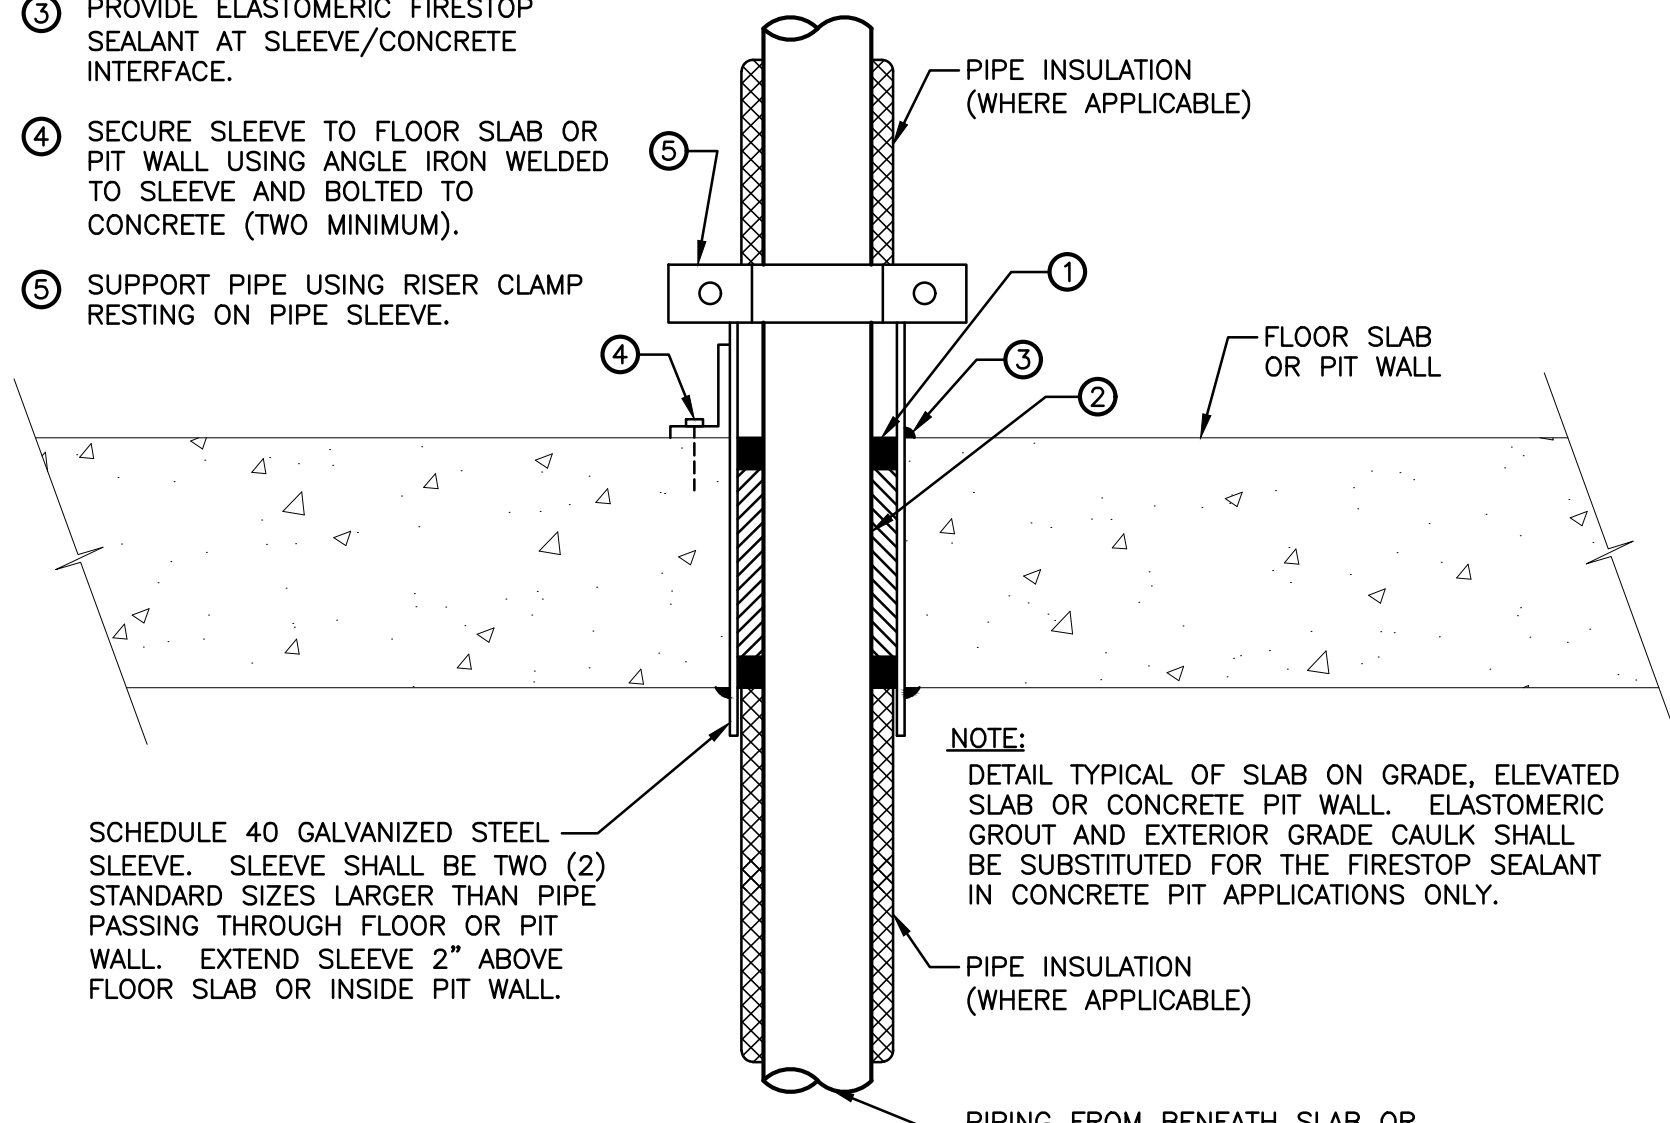


10 TYPICAL PIPING CONCRETE PENETRATION DETAIL
N.T.S.

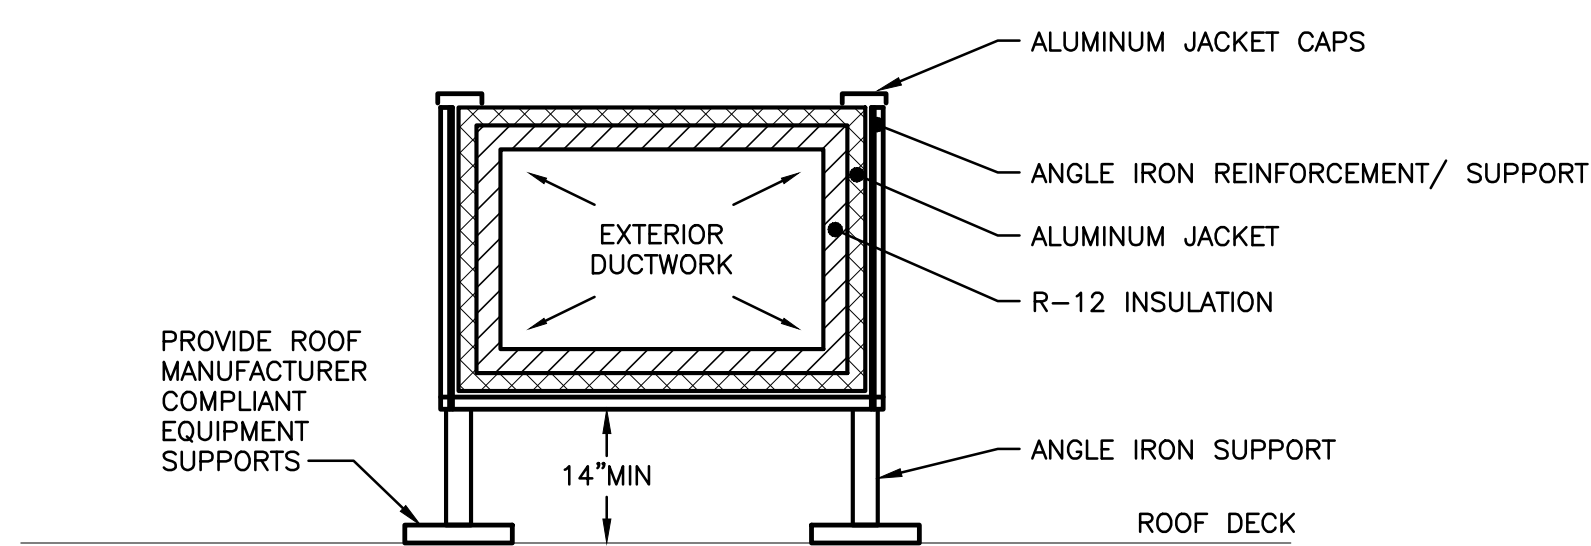

- NOTES:
1. SEAL ALL DUCTWALL PENETRATIONS AT POINTS OF SUPPORT ATTACHMENT AND REINFORCEMENT ATTACHMENT.
 2. WATERPROOF ALL SEAMS AND JOINTS IN DUCTS.


11 EXTERIOR INSULATED DUCTWORK DETAIL
N.T.S.

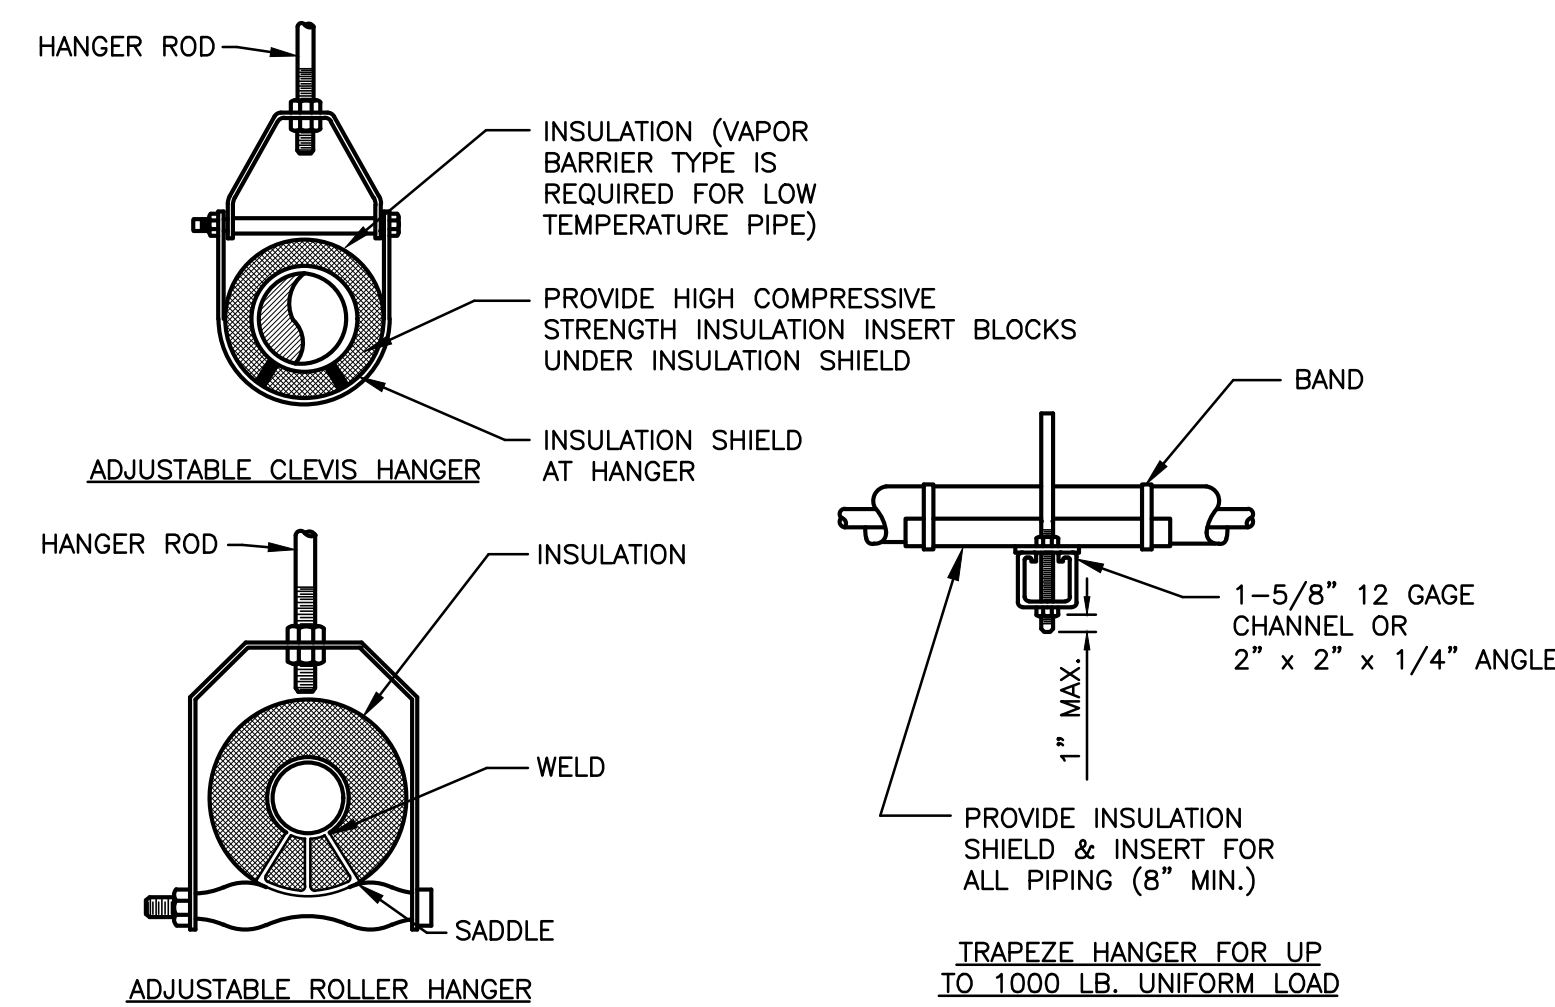

INDIVIDUAL PIPE HANGER ROD & SPACING SCHEDULE

[illegible]

9 TYPICAL PIPE HANGERS


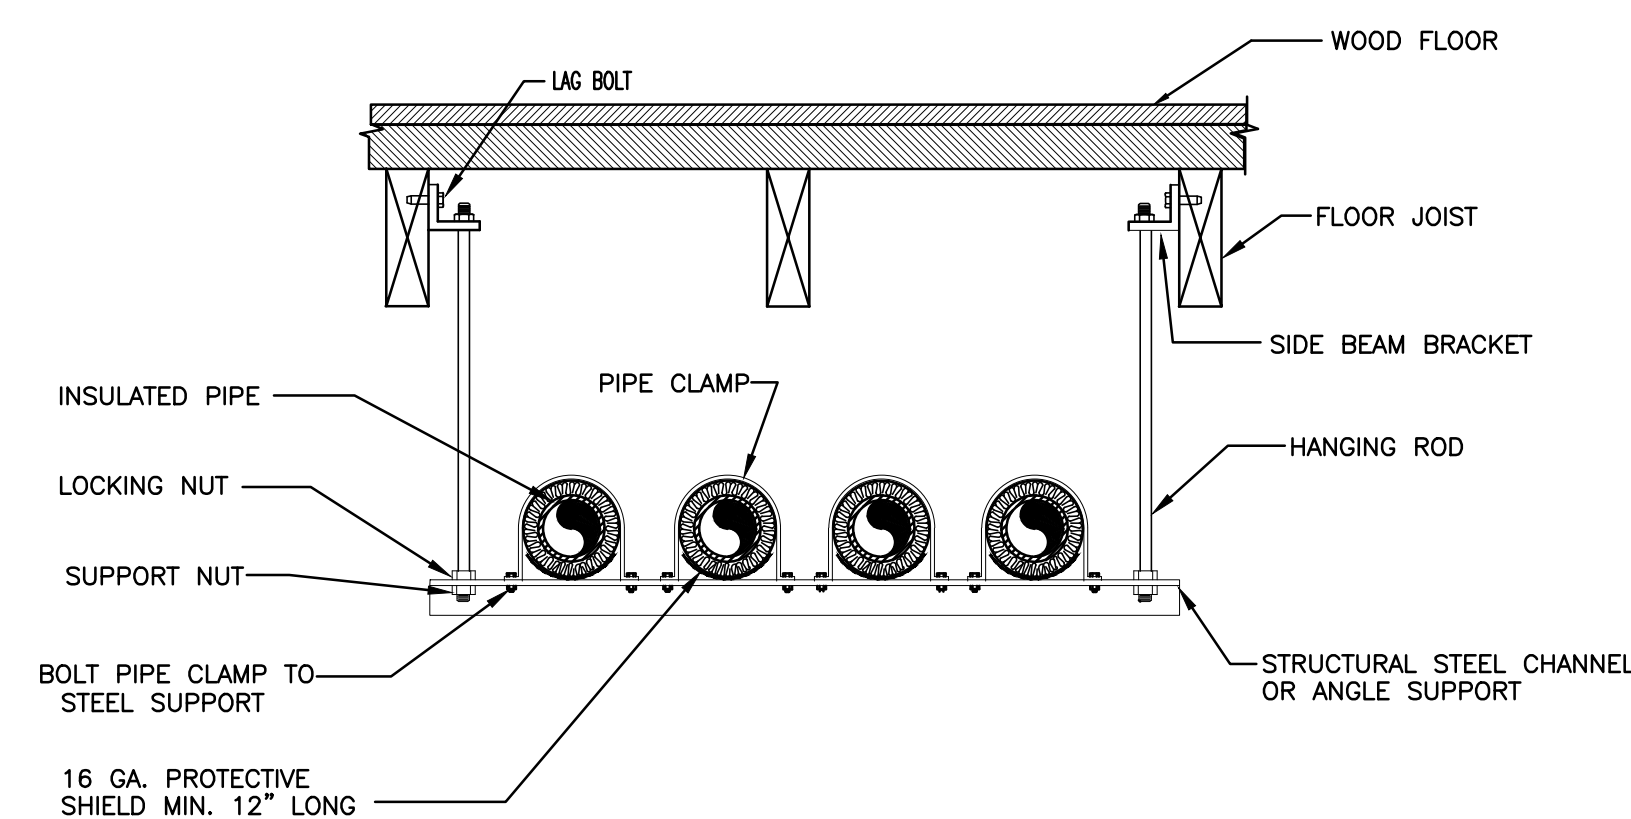


12 **TYPICAL TRAPEZE HANGER SUPPORT DETAIL**
N.T.S.

PIPE HANGER ROD AND SPACING SCHEDULE									
NOMINAL PIPE OR TUBE SIZE - INCHES	3/4	7/8	1	1 1/2	2	2 1/2	-	-	-
HANGER ROD SIZES INCHES	3/8	3/8	3/8	3/8	3/8	1/2	-	-	-
MAX. SPACING BETWEEN PIPE SUPPORTS - FEET	6	-	7	9	10	11	-	-	-
MAX. SPACING BETWEEN CU. TUBE SUPPORTS - FT.	6	6	6	8	9	10	-	-	-

NOTES: TRAPPIPE HANGER SPACING SHALL BE BASED ON SPACING OF SMALLEST PIPE ON LOAD.
 TRAPPIPE SHALL BE DESIGNED WITH A FACTOR OF 5 FOR CENTER OF SPAN CONCENTRATED LOAD.

 - NOTES: TRAPEZE HANGER SPACING SHALL BE BASED ON SPACING OF SMALLEST PIPE ON TRAPEZE.
TRAPEZE SHALL BE DESIGNED WITH A FACTOR OF 5 FOR CENTER OF SPAN CONCENTRATED LOAD.

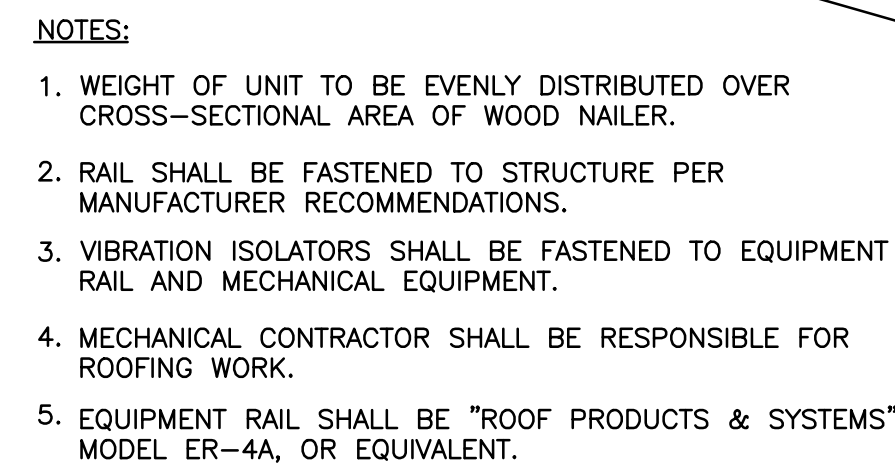

1. ATC TO INTERFACE WITH UNIT MANUFACTURERS' FURNISHED ENERGY WHEEL CONTROLS.
2. 24V DUCT SMOKE DAMPER FURNISHED AND INSTALLED BY MECHANICAL CONTRACTOR, WIRED BY DIV. 26000 AND DUCT SMOKE DETECTOR FURNISHED, INSTALLED AND WIRED BY DIV. 26000.
3. AIR FLOW MEASUREMENT STATION FURNISHED BY UNIT MANUFACTURER WITH OUTPUT SIGNAL INTERFACE CAPABILITY TO ATC.
4. FURNISHED BY UNIT MANUFACTURER.
5. CONTROLLER PROVIDED BY ATC.
6. CONTRACTOR SHALL REFER TO EQUIPMENT SCHEDULE SHEET & FLOOR PLANS FOR QUANTITIES OF UNITS.
7. ALL CONTROL WIRING BY HVAC.



**538 Broad Hollow Road, 4th Floor East
Melville, NY 11747
631.756.8000 • www.h2m.com**

CONSULTANTS:

FELLENZER 
ENGINEERING LLP

22 Mulberry St., Suite 2A,
Middletown, NY 10940
t 845-343-1481 fx 855-320-8735

[illegible]

"ALTERATION OF THIS DOCUMENT EXCEPT BY A LICENSED PROFESSIONAL IS ILLEGAL."			
DESIGNED BY: PMC	DRAWN BY: SRB	CHECKED BY: EDF	REVIEWED BY: MDF
PROJECT No: FILB 1501	DATE: 11/15/19	SCALE: AS SHOWN	

CLIENT

**Montebello Realty
GP LLC**

**Braemar at Montebello Assisted
Living Residence**

**Montebello Crossing,
250 Lafayette Avenue
(Route 59)
Village of Montebello
New York**

CONTRACT

FOR CONSTRUCTION

SHEET TITLE

HVAC: DETAILS

DRAWING No.

H7.3

HEET No. _____
OF _____



CLIENT
**Montebello Realty
GP LLC**

**Braemar at Montebello Assisted
Living Residence**

**Montebello Crossing,
250 Lafayette Avenue
(Route 59)
Village of Montebello
New York**

CONTRACT

STATUS	FOR CONSTRUCTION
--------	------------------

SHEET TITLE

**HVAC:
DETAILS**

DRAWING No. **H7.5**

File Name: E:\09\15-1454 NEW ASSSTED LIVING RESIDENCE\H8.1.dwg (Layout: H8.1)
Date Mon, Aug 08, 2022 2:30 AM (Name: ah)

PUMP SCHEDULE													MANUFACTURER AS INDICATED OR APPROVED EQUAL			
UNIT NO.	LOCATION	SYSTEM	CIRCULATING FLUID				MOTOR HP (WATTS)	MOTOR RPM	MOTOR SPEED	IMPELLER DIAMETER (IN.)	MIN. EFF. (%)	ELECTRICAL DATA VOLT/PH	MANUFACTURER	MODEL NO.	REMARKS	
			FLUID	SPEC. GRAVITY	TEMP. (°F)	GPM										HEAD (FT.)
RP-1	BASEMENT MER	DOMESTIC HOT WATER	PLAIN WATER	1.0	110	14.6	15	1/8	1725	CV	—	65	120/1	TACO	0011 BF	1, 2, 3
RP-2	BASEMENT MER	KITCHEN HOT WATER	PLAIN WATER	1.0	140	11.2	15	1/8	1725	CV	—	65	120/1	TACO	0011 BF	1, 2, 3

NOTES:

- IMPELLER DIAMETER INDICATED IS APPROXIMATE. FINAL IMPELLER DIAMETER TO BE DETERMINED BY PUMP MFR. CONTRACTOR SHALL TRIM IMPELLER AFTER INITIAL FLOW BALANCING TO ACHIEVE OPTIMAL PUMP PERFORMANCE.
- COORDINATE MOTOR REQ. WITH E.C. E.C. TO FURNISH AND INSTALL MOTOR STARTERS.
- DOMESTIC HOT WATER RECIRCULATION PUMPS SHALL BE OF BRONZE CONSTRUCTION.

Energy Recovery Ventilator Schedule																																
Unit No.	CFM		Supply Fan Data				Exhaust Fan Data			Media Type	Wheel Face Area (ft²/side)	Summer Operation								Winter Operation								Volt/Phase	MCA	MOCP	Manufacturer & Model	Weight (lbs)
	R.A.	S.A.	ESP (in. w.c.)	Motor HP	Motor RPM	ESP in. w.c.	Motor HP	Motor RPM	O.A. (°F) DB/WB			R.A. (°F) DB/WB	E.A. (°F) DB/WB	S.A. (°F) DB/WB	Tot Eff. (%)	En. Rec. Total/Sensible (MBH)	O.A. (°F) DB/WB	R.A. (°F) DB/WB	E.A. (°F) DB/WB	S.A. (°F) DB/WB	Tot Eff. (%)	En. Rec. Total/Sensible (MBH)										
ERV-1	3470	3470	1	5	1750	1	5	1750	3A Molecular Sieve Coated Aluminum	14.00	92.0/74.0	75.0/62.5	88.5/72.0	78.1/64.6	82	52.2 / 117.1	12.0/10.4	70/58.5	23.5/22.6	58.7/52.1	81	175.1 / 271.6	460/3	18.3	20	AVS040-R-FRVE	1,700					
ERV-2	5725	5725	1	5	1750	1	5	1750	3A Molecular Sieve Coated Aluminum	24.00	92.0/74.0	75.0/62.5	88.5/72.0	78.1/64.6	82	86.3 / 193.8	12.0/10.4	70/58.5	23.4/22.5	58.8/52.1	81	289.3 / 448.8	460/3	18.3	20	AVS065-R-FRVE	2,300					
ERV-3	5475	5475	1	5	1750	1	5	1750	3A Molecular Sieve Coated Aluminum	24.00	92.0/74.0	75.0/62.5	88.6/72.0	78.0/64.5	83	83.0 / 186.2	12.0/10.4	70/58.5	23.2/22.3	59.1/52.3	81	278.5 / 431.8	460/3	18.3	20	AVS065-R-FRVE	2,300					
ERV-4	7100	7100	1	5	1750	1	5	1750	3A Molecular Sieve Coated Aluminum	30.00	92.0/74.0	75.0/62.5	88.5/72.0	78.1/64.6	82.00	106.8 / 240.1	12.0/10.4	70/58.5	23.5/22.6	58.7/52.1	81.00	358.1 / 555.7	460/3	18.3	20	AVS085-R-FRVE	2,600					

Expansion Tank Schedule												
Unit No.	System and/or Service	Type	Approx. System Volume (Gal)	System Temperature Range Min. (°F)	Max. (°F)	Initial Pressure in Tank (PSI)	Max Operating Pressure (PSI)	Fill Pressure at Tank Relief Valve (PSI)	Alt Tank (PSI)	Min. Volume Tank (Gal)	Min. Bladder Volume (Gal)	Make-Up Water Fill Size (in.)
ET-1	Hot Water	Bladder	365	60	160	12	30	75	23	34	14.25	1

Packaged Terminal AC Unit Schedule															
Unit No.	CFM		Cooling (MBH)	Heating		Refrig.	Electrical Data				Weight (lbs)	EER	Manufacturer & Model	Total Number of Units	Remarks
	Total	Min. O.A.	Total	Output (MBH)	Electric Heat (KW)		Volt/PH	MCA	MOCP	Receptacle					
PTAC-1	383	25	7.2	6.1	2	R-410A	277/1	9.7	15	NEMA 7-20R	99	12.3	Polar Air iPTAC-HEH-07-Z	130	----
PTAC-2	383	25	7.2	6.1	3	R-410A	277-1	14.4	15	NEMA 7-20R	99	12.3	Polar Air iPTAC-HEH-07-Z	52	----
PTAC-3	383	25	9.5	8.5	3	R-410A	277/1	14.4	15	NEMA 7-20R	108	12.1	Polar Air iPTAC-HEH-09-Z	10	----
PTAC-4	383	25	9.5	8.5	3.6	R-410A	277/1	17.2	20	NEMA 7-20R	108	12.1	Polar Air iPTAC-HEH-09-Z	6	----
PTAC-5	400	25	12.5	11.4	3.6	R-410A	277/1	17.2	20	NEMA 7-20R	110	11.7	Polar Air iPTAC-HEH-12-Z	2	----

NOTES:

- PROVIDE ALL PTAC UNITS WITH INSULATED WALL SLEEVE (SHIPPED FLAT).
- PROVIDE ALL PTAC UNITS WITH ARCHITECTURAL OUTDOOR GRILLE.
- PROVIDE ALL PTAC UNITS WITH A CONDENSATE DRAIN PAN KIT.
- PROVIDE ALL PTAC UNITS WITH ELECTRICAL SUBBASE THAT INCLUDES FACTORY INSTALLED NEMA 7-20R RECEPTACLE.

ROOM #	TYPE OF PTAC UNIT
1126	PTAC-2
1125	PTAC-1
1125A	PTAC-2
1124	PTAC-1
1124A	PTAC-2
1123	PTAC-1
1121	PTAC-1
1121A	PTAC-1
1119	PTAC-1
1117	PTAC-1
1115	PTAC-1
1115A	PTAC-1
1113	PTAC-1
1113A	PTAC-1
1111	PTAC-1
1109	PTAC-2
1107	PTAC-1
1105	PTAC-1
1105A	PTAC-1

ROOM #	TYPE OF PTAC UNIT
1223	PTAC-1
1221	PTAC-1
1221A	PTAC-1
1219	PTAC-1
1217	PTAC-1
1215	PTAC-1
1215A	PTAC-1
1213	PTAC-1
1213A	PTAC-1
1211	PTAC-1
1207	PTAC-1
1205	PTAC-1
1205A	PTAC-1

ROOM #	TYPE OF PTAC UNIT
2126	PTAC-1
2125	PTAC-3
2125A	PTAC-1
2124	PTAC-3
2124A	PTAC-1
2123	PTAC-1
2122	PTAC-1
2121	PTAC-1
2121A	PTAC-1
2120	PTAC-1
2120A	PTAC-1
2119	PTAC-1
2118	PTAC-1
2118A	PTAC-1
2117	PTAC-1
2116	PTAC-1
2114	PTAC-3
2112	PTAC-1

ROOM #	TYPE OF PTAC UNIT
3126	PTAC-2
3125	PTAC-3
3125A	PTAC-1
3124	PTAC-1
3124A	PTAC-3
3123	PTAC-1
3122	PTAC-1
3121	PTAC-1
3121A	PTAC-1
3120	PTAC-1
3120A	PTAC-1
3119	PTAC-1
3118	PTAC-1
3118A	PTAC-1
3117	PTAC-1
3116	PTAC-1
3115	PTAC-1
3115A	PTAC-1
3114	PTAC-3
3113	PTAC-1
3113A	PTAC-1
3112	PTAC-1
3111	PTAC-1
3110	PTAC-1
3110A	PTAC-1
3109	PTAC-1
3109A	PTAC-1
3108	PTAC-1
3108A	PTAC-1
3107	PTAC-1
3106	PTAC-1
3104	PTAC-1
3104A	PTAC-1
3102	PTAC-1
3102A	PTAC-1

ROOM #	TYPE OF PTAC UNIT
3226	PTAC-2
3225	PTAC-3
3225A	PTAC-1
3224	PTAC-1
3224A	PTAC-3
3223	PTAC-1
3222	PTAC-1
3221	PTAC-1
3221A	PTAC-1
3220	PTAC-1
3220A	PTAC-1
3219	PTAC-1
3218	PTAC-1
3218A	PTAC-1
3217	PTAC-1
3216	PTAC-1
3215	PTAC-1
3215A	PTAC-1
3214	PTAC-2
3213	PTAC-1
3213A	PTAC-1
3212	PTAC-1
3211	PTAC-1
3210	PTAC-1
3210A	PTAC-1
3209	PTAC-1
3209A	PTAC-2
3208	PTAC-1
3208A	PTAC-1
3207	PTAC-1
3206	PTAC-1
3204	PTAC-1
3204A	PTAC-1
3202	PTAC-1
3202A	PTAC-1

ROOM #	TYPE OF PTAC UNIT
4126	PTAC-2
4125	PTAC-1
4125A	PTAC-1
4124	PTAC-4
4124A	PTAC-1
4123	PTAC-2
4122	PTAC-2
4121	PTAC-2
4121A	PTAC-1
4120	PTAC-2
4120A	PTAC-2
4119	PTAC-2
4118	PTAC-2
4118A	PTAC-1
4117	PTAC-2
4116	PTAC-2
4115	PTAC-1
4115A	PTAC-2
4114	PTAC-3
4113	PTAC-1
4113A	PTAC-2
4112	PTAC-2
4111	PTAC-2
4110	PTAC-2
4110A	PTAC-1
4109	PTAC-1
4109A	PTAC-2
4108	PTAC-1
4108A	PTAC-2
4107	PTAC-2
4106	PTAC-2
4105	PTAC-1
4105A	PTAC-2
4104	PTAC-1
4104A	PTAC-2
4103	PTAC-1
4103A	PTAC-2
4102	PTAC-1
4102A	PTAC-2
4101	PTAC-2

ROOM #	TYPE OF PTAC UNIT
4226	PTAC-2
4225	PTAC-1
4225A	PTAC-1
4224	PTAC-4
4224A	PTAC-1
4223	PTAC-2
4222	PTAC-2
4221	PTAC-1
4221A	PTAC-2
4220	PTAC-1
4220A	PTAC-2
4219	PTAC-2
4218	PTAC-1
4218A	PTAC-2
4217	PTAC-2
4216	PTAC-2
4215	PTAC-1
4215A	PTAC-2
4214	PTAC-3
4213	PTAC-1
4213A	PTAC-2
4212	PTAC-2
4211	PTAC-2
4210	PTAC-1
4210A	PTAC-2
4209	PTAC-1
4209A	PTAC-2
4208	PTAC-1
4208A	PTAC-2
4207	PTAC-2
4206	PTAC-2
4205	PTAC-4
4205A	PTAC-5
4204	PTAC-1
4204A	PTAC-2
4203	PTAC-4
4203A	PTAC-5
4202	PTAC-1
4202A	PTAC-2
4201	PTAC-2

Return/Exhaust Grill Schedule							
Symbol	CFM Range	Neck Size (in.)	Nom. Face Size (in.)	Blade Deflection	Blade Spacing (in.)	Finish	Manufacturer & Model No.
RG-1	0-110	6x6	12x12	35°	3/4	White	Titus 350RL
RG-2	0-110	6x6	24x24	35°	3/4	White	Titus 350RL
RG-3	111-170	8x6	24x24	35°	3/4	White	Titus 350RL
RG-4	171-220	10x6	24x24	35°	3/4	White	Titus 350RL
RG-5	221-320	10x8	24x24	35°	3/4	White	Titus 350RL
RG-6	321-425	10x10	24x24	35°	3/4	White	Titus 350RL
RG-7	426-525	12x12	24x24	35°	3/4	White	Titus 350RL
RG-8	526-730	14x14	24x24	35°	3/4	White	Titus 350RL
RG-9	731-820	16x16	24x24	35°	3/4	White	Titus 350RL
RG-10	821-1035	18x18	24x24	35°	3/4	White	Titus 350RL
RG-11	1475	48x18	48x18	35°	3/4	White	Titus 350RL
RG-12	1036-1570	22x22	24x24	35°	3/4	White	Titus 350RL
RG-13	100-380	—	18x6	35°	3/4	White	Titus 350RL
EG-1	0-110	6x6	12x12	35°	3/4	White	Titus 350RL
EG-2	0-110	6x6	24x24	35°	3/4	White	Titus 350RL
EG-3	111-170	8x6	24x24	35°	3/4	White	Titus 350RL
EG-4	171-220	10x6	24x24	35°	3/4	White	Titus 350RL
EG-5	221-320	10x8	24x24	35°	3/4	White	Titus 350RL
EG-6	321-425	10x10	24x24	35°	3/4	White	Titus 350RL
EG-7	426-525	12x12	24x24	35°	3/4	White	Titus 350RL
EG-8	526-730	14x14	24x24	35°	3/4	White	Titus 350RL
EG-9	731-820	16x16	24x24	35°	3/4	White	Titus 350RL
EG-10	821-1035	18x18	24x24	35°	3/4	White	Titus 350RL
EG-11	100-380	—	18x6	35°	3/4	White	Titus 350RL

Exhaust Fan Schedule									
Unit No.	System and/or Service	Location	Manufacturer & Model	Air Flow (CFM)	Total Static Pressure (in. w.c.)	Drive	Fan RPM	Nominal Power (HP)	Phase
EF-1	Dwelling Unit Bathroom	Roof	Twin Cities 0908E	600	0.5	Direct	1650	1/6	1
EF-2	Dwelling Unit Bathroom	Roof	Twin Cities 1008E	1050	0.75	Direct	1750	1/4	1
EF-3	Dwelling Unit Bathroom	Roof	Twin Cities 1208E	1400	0.75	Direct	1750	1/2	1
EF-4	Dwelling Unit Bathroom	Roof	Twin Cities 0958E	650	0.75	Direct	1575	1/4	1
EF-5	Dwelling Unit Bathroom	Roof	Twin Cities 0958E	700	0.5	Direct	1575	1/4	1</

File Name: F:\2016\15-1461 NEW ASSISTED LIVING RESIDENCE\H8.2.dwg (Layout: H8.2)
Date: Mon, Aug 08, 2022 2:30 AM (Name: ah)

Fan Coil Unit Schedule																				
Unit No.	Location	CFM		Fan Data		Corrected Cooling Capacity (MBH)		Cooling Air Data		Cooling Coil Data		Corrected Heating Capacity (MBH)	Heating Air Data		Filter Data		Electrical Data		LG Model #	Remarks
		Total	Min. O.A	Drive	Motor Qty.	Total	Sensible	EAT (°F)	LAT (°F)	Fluid	EAT (°F)		LAT (°F)	Type	Volt/PH	MCA				
Basement																				
FCU B01	Room 1021	600	200	Direct	1	19.4	15.8	77.00	52.5	R410A	26.8	63.3333	105.2	3/16" Washable	208/1	2.3	ARNU243M2A4		MAX. ESP =0.7	
FCU B02	Room 1017	680	110	Direct	1	22	17.9	75.97	52.5	R410A	29.4	66.7647	105.2	3/16" Washable	208/1	2.3	ARNU243M2A4		MAX. ESP =0.7	
FCU B03	Room 1018	430	70	Direct	1	10.9	8.9	75.98	57.5	R410A	14.9	66.7442	96.8	3/16" Washable	208/1	2.3	ARNU183M2A4		MAX. ESP =0.7	
FCU B04	Room 1016	760	360	Direct	1	24.5	19.6	77.84	53.1	R410A	33.0	60.5263	101.9	3/16" Washable	208/1	2.3	ARNU243M2A4		MAX. ESP =0.7	
FCU B05	Room 1007	595	100	Direct	1	18.8	15.5	76.01	52	R410A	25.5	66.6387	106.2	3/16" Washable	208/1	2.3	ARNU243M2A4		MAX. ESP =0.7	
FCU B06	Room 1027	410	130	Direct	1	16.2	13.2	76.90	52.6	R410A	22.3	63.6585	105.2	3/16" Washable	208/1	2.3	ARNU243M2A4		MAX. ESP =0.7	
FCU B07	Room 1004	340	50	Direct	1	9	9.0	75.88	52.4	R410A	11.9	67.0588	96	3/16" Washable	208/1	2.3	ARNU153M2A4		MAX. ESP =0.7	
FCU B08	Room 1066	500	170	Direct	1	15.9	15.9	77.04	47.8	R410A	21.2	63.2	101.7	3/16" Washable	208/1	2.3	ARNU243M2A4		MAX. ESP =0.7	
FCU B09	Room 1067	430	90	Direct	1	10.8	10.8	76.26	53.4	R410A	14.4	65.814	95.4	3/16" Washable	208/1	2.3	ARNU183M2A4		MAX. ESP =0.7	
FCU B10	Room 1030	500	210	Direct	1	15.9	15.9	77.52	48.2	R410A	21.2	61.6	100.3	3/16" Washable	208/1	2.3	ARNU243M2A4		MAX. ESP =0.7	
FCU B11A-1	Room 1032	1600	335	Direct	1	31.8	20.6	76.26	65.4	R410A	42.2	65.8125	86.7	3/16" Washable	208/1	2.5	ARNU283M3A4		MAX. ESP =0.7	
FCU B11B-1	Room 1032	720	670	Direct	1	22.9	16.7	80.58	59.2	R410A	30.5	51.3889	98.1	3/16" Washable	208/1	2.3	ARNU243M2A4		MAX. ESP =0.7	
FCU B11C-1	Room 1032	825	335	Direct	1	26.3	17.3	77.44	58.1	R410A	34.9	61.8788	101	3/16" Washable	208/1	2.3	ARNU243M2A4		MAX. ESP =0.7	
FCU B11A-2	Room 1032	1600	335	Direct	1	31.8	34.5	76.26	65.4	R410A	42.2	65.8125	86.7	3/16" Washable	208/1	2.5	ARNU283M3A4		MAX. ESP =0.7	
FCU B11B-2	Room 1032	720	670	Direct	1	22.9	24.0	80.58	59.2	R410A	30.5	51.3889	98.1	3/16" Washable	208/1	2.3	ARNU243M2A4		MAX. ESP =0.7	
FCU B11C-2	Room 1032	825	335	Direct	1	26.3	24.0	77.44	58.1	R410A	34.9	61.8788	101	3/16" Washable	208/1	2.3	ARNU243M2A4		MAX. ESP =0.7	
FCU B12	Room 1064	875	190	Direct	1	27.9	17.2	76.30	59.7	R410A	37.0	65.6571	99.6	3/16" Washable	208/1	2.3	ARNU243M2A4		MAX. ESP =0.7	
FCU B13	Room 1034	1600	310	Direct	1	31.1	27.9	76.16	60.9	R410A	41.4	66.125	87.1	3/16" Washable	208/1	5.2	ARNU423B8A4		MAX. ESP =0.7	
FCU B14	Room 1035	645	380	Direct	1	22	17.5	78.53	53.5	R410A	29.3	58.2171	100.9	3/16" Washable	208/1	2.3	ARNU243M2A4		MAX. ESP =0.7	
FCU B15	Room 1060	338	338	Direct	1	8.2	6.4	81.00	63.6	R410A	10.1	50	86.5	3/16" Washable	208/1	2.3	ARNU243M2A4		MAX. ESP =0.7	
FCU B16	Room 1059	430	430	Direct	1	15.6	12.0	81.00	54.9	R410A	19.5	50	100.9	3/16" Washable	208/1	2.3	ARNU243M2A4		MAX. ESP =0.7	
FCU B17	Room 1051	430	430	Direct	1	15.6	12.1	81.00	54.9	R410A	19.5	50	100.9	3/16" Washable	208/1	2.3	ARNU243M2A4		MAX. ESP =0.7	
FCU B18	Room 1039	510	300	Direct	1	17.4	13.9	78.53	53.4	R410A	23.2	58.2353	100.9	3/16" Washable	208/1	2.3	ARNU243M2A4		MAX. ESP =0.7	
FCU B19	Room 1043	545	140	Direct	1	17.5	14.3	76.54	52.3	R410A	24.0	64.8624	105.5	3/16" Washable	208/1	2.3	ARNU243M2A4		MAX. ESP =0.7	
FCU B20	Room 1048	430	160	Direct	1	14.4	11.6	77.23	53.2	R410A	19.4	62.5581	101.7	3/16" Washable	208/1	2.3	ARNU243M2A4		MAX. ESP =0.7	
FCU B21	Room 1049	680	290	Direct	1	22.5	18.1	77.56	52.9	R410A	30.6	61.4706	103	3/16" Washable	208/1	2.3	ARNU243M2A4		MAX. ESP =0.7	
FCU B22	Room 1042	500	200	Direct	1	19.7	15.9	77.40	52.8	R410A	22.4	62	103.4	3/16" Washable	208/1	2.3	ARNU243M2A4		MAX. ESP =0.7	
FCU B23	Room 1046	600	230	Direct	1	19.7	15.9	77.30	52.8	R410A	26.9	62.3333	103.7	3/16" Washable	208/1	2.3	ARNU243M2A4		MAX. ESP =0.7	
FIRST FLOOR																				
FCU 101	Room 2012	500	60	Direct	1	12.5	10.3	75.72	57.1	R410A	17.3	67.6	98.4	3/16" Washable	208/1	2.3	ARNU183M2A4		MAX. ESP =0.7	
FCU 102	Room 2010	500	280	Direct	1	15.8	12.5	78.36	53.5	R410A	20.2	58.8	99.5	3/16" Washable	208/1	2.3	ARNU243M2A4		MAX. ESP =0.7	
FCU 103	Room 2009	425	70	Direct	1	10.8	8.8	75.99	57.5	R410A	14.7	66.7059	96.6	3/16" Washable	208/1	2.3	ARNU183M2A4		MAX. ESP =0.7	
FCU 104	Room 2010	430	170	Direct	1	14.2	11.5	77.37	52.9	R410A	18.9	62.093	102.2	3/16" Washable	208/1	2.3	ARNU243M2A4		MAX. ESP =0.7	
FCU 105	Room 2022	770	370	Direct	1	25.8	20.7	77.88	53.1	R410A	33.8	60.3896	100.9	3/16" Washable	208/1	2.3	ARNU243M2A4		MAX. ESP =0.7	
FCU 106	Room 2023	430	290	Direct	1	15.2	11.9	79.05	54.2	R410A	18.9	56.5116	99.5	3/16" Washable	208/1	2.3	ARNU243M2A4		MAX. ESP =0.7	
FCU 107	Room 2008	810	330	Direct	1	26.7	21.6	77.44	52.8	R410A	35.5	61.8519	102.4	3/16" Washable	208/1	2.3	ARNU243M2A4		MAX. ESP =0.7	
FCU 108	Room 2007	810	280	Direct	1	26.7	21.6	77.07	52.8	R410A	35.5	63.0864	102.4	3/16" Washable	208/1	2.3	ARNU243M2A4		MAX. ESP =0.7	
FCU 109A	Room 2005	1350	310	Direct	2	28.5	28.5	76.38	57.7	R410A	35.3	65.4074	86.8	3/16" Washable	208/1	5.2	ARNU483B8A4		MAX. ESP =0.7	
FCU 109B	Room 2005	750	250	Direct	1	23.9	17.4	77.00	55.7	R410A	29.6	63.3333	99.3	3/16" Washable	208/1	2.3	ARNU243M2A4		MAX. ESP =0.7	
FCU 110	Room 2025	700	330	Direct	1	17.6	13.1	77.83	63.7	R410A	21.8	60.5714	87.7	3/16" Washable	208/1	2.3	ARNU183M2A4		MAX. ESP =0.7	
FCU 111	Room 2029	750	250	Direct	1	18.9	13.1	77.00	64.8	R410A	23.3	63.3333	87.7	3/16" Washable	208/1	2.3	ARNU183M2A4		MAX. ESP =0.7	
FCU 112A-1	Room 2031	1600	325	Direct	2	32.4	24.0	76.22	64.6	R410A	40.1	65.9375	85.3	3/16" Washable	208/1	5.2	ARNU363B8A4		MAX. ESP =0.7	
FCU 112B-1	Room 2031	800	550	Direct	1	27.1	16.9	79.13	59.9	R410A	33.5	56.25	95.4	3/16" Washable	208/1	2.3	ARNU243M2A4		MAX. ESP =0.7	
FCU 112C-1	Room 2031	850	480	Direct	1	27.1	17.0	78.39	60.9	R410A	33.5	58.7059	95.4	3/16" Washable	208/1	2.3	ARNU243M2A4		MAX. ESP =0.7	
FCU 112A-2	Room 2031	1600	325	Direct	2	32.4	24.0	76.22	64.6	R410A	40.1	65.9375	85.3	3/16" Washable	208/1	5.2	ARNU363B8A4		MAX. ESP =0.7	
FCU 112B-2	Room 2031	800	550	Direct	1	25.5	16.9	79.13	59.9	R410A	33.5	56.25	95.4	3/16" Washable	208/1	2.3	ARNU243M2A4		MAX. ESP =0.7	
FCU 112C-2	Room 2031	850	480	Direct	1	27.1	17.0	78.39	60.9	R410A	33.5	58.7059	95.4	3/16" Washable	208/1	2.3	ARNU243M2A4		MAX. ESP =0.7	
FCU 114	Room 2002	760	230	Direct	1	18.9	13.6	76.82	61	R410A	23.3	63.9474	89.5	3/16" Washable	208/1	2.3	ARNU183M2A4		MAX. ESP =0.7	
FCU 115	Room 2033	550	120	Direct	1	17.5	17.5	76.31	47.2	R410A	21.7	65.6364	101.4	3/16" Washable	208/1	2.3	ARNU243M2A4		MAX. ESP =0.7	
FCU 116	Room 2078	520	150	Direct	1	16.6	16.6	76.73	47.6	R410A	20.5	64.2308	99.7	3/16" Washable	208/1	2.3	ARNU243M2A4		MAX. ESP =0.7	
FCU 117	Room 2078	800	250	Direct	1	20.1	13.6	76.88	61.9	R410A	24.9	63.75	90.1	3/16" Washable	208/1	2.3	ARNU183M2A4		MAX. ESP =0.7	
FCU 118	Room 2033	450	230	Direct	1	14.3	14.3	78.07	49.1	R410A	17.7	59.7778	95.4	3/16" Washable	208/1	2.3	ARNU243M2A4		MAX. ESP =0.7	
FCU 119	Room 2035	1650	340	Direct	2	34.8	31.9	76.24	59.1	R410A	43.1	65.8788	87.3	3/16" Washable	208/1	5.2	ARNU483B8A4		MAX. ESP =0.7	
FCU 120	Room 2035A	1600	170	Direct	1	32.4	20.7	75.64	65.5	R410A	44.9	67.875	88	3/16" Washable	208/1	2.5	ARNU283M3A4		MAX. ESP =0.7	
FCU 121A	Room 2035B	1600	85	Direct	1	32	12.1	75.32	64	R410A	44.4	68.9375	91.8	3/16" Washable	208/1	2.5	ARNU283M3A4		MAX. ESP =0.7	
FCU 121B	Room 2035B	1600	205	Direct	1	32	21.1	75.77	64	R410A	44.4	67.4375	91.8	3/16" Washable	208/1	2.5	ARNU283M3A4		MAX. ESP =0.7	
FCU 122	Room 2073	610	350	Direct	1	19.6	17.3	78.44	51.9	R410A	27.2	58.5246	100.9	3/16" Washable	208/1	2.3	ARNU243M2A4		MAX. ESP =0.7	

Fan Coil Unit Schedule																			
FCU 123	Room 2074	650	180	Direct	1	17.4	11.2	76.66	61.3	R410A	24.2	64.4615	97.2	3/16" Washable	208/1	2.3	ARNU153M2A4	MAX. ESP =0.7	
FCU 124	Room 2075	550	260	Direct	1	17.6	17.3	77.84	48.7	R410A	24.5	60.5455	101.6	3/16" Washable	208/1	2.3	ARNU243M2A4	MAX. ESP =0.7	
FCU 125A	Room 2069	500	315	Direct	1	16	16.0	78.78	49.2	R410A	22.3	57.4	100.1	3/16" Washable	208/1	2.3	ARNU243M2A4	MAX. ESP =0.7	
FCU 125B	Room 2069	500	315	Direct	1	16	16.0	78.78	49.2	R410A	22.3	57.4	100.1	3/16" Washable	208/1	2.3	ARNU243M2A4	MAX. ESP =0.7	
FCU 126	Room 2066	780	350	Direct	1	25	17.4	77.69	57.2	R410A	34.7	61.0256	102.1	3/16" Washable	208/1	2.3	ARNU243M2A4	MAX. ESP =0.7	
FCU 127	Room 2052	1350	190	Direct	1	27	21.0	75.84	62.1	R410A	37.4	67.1852	90.9	3/16" Washable	208/1	2.5	ARNU283M3A4	MAX. ESP =0.7	
FCU 128	Room 2043	430	210	Direct	1	13.8	13.8	77.93	48.3	R410A	19.1	60.2326	101.3	3/16" Washable	208/1	2.3	ARNU243M2A4	MAX. ESP =0.7	
FCU 129	Room 2046	690	220	Direct	1	22.5	17.5	76.91	53.8	R410A	31.2	63.6232	104.7	3/16" Washable	208/1	2.3	ARNU243M2A4	MAX. ESP =0.7	
FCU 130	Room 2054	550	260	Direct	1	17.6	17.3	77.84	48.7	R410A	24.5	60.5455	101.6	3/16" Washable	208/1	2.3	ARNU243M2A4	MAX. ESP =0.7	
FCU 131	Room 2065	550	200	Direct	1	17.6	17.4	77.18	48.4	R410A	24.5	62.7273	102.6	3/16" Washable	208/1	2.3	ARNU243M2A4	MAX. ESP =0.7	
FCU 132	Room 2060	850	300	Direct	1	27.3	17.4	77.12	58.6	R410A	37.8	62.9412	102.6	3/16" Washable	208/1	2.3	ARNU243M2A4	MAX. ESP =0.7	
FCU 133	Room 2061	338	80	Direct	1	7.1	7.1	76.42	61.9	R410A	10.0	65.2663	86.5	3/16" Washable	208/1	2.3	ARNU243M2A4	MAX. ESP =0.7	
Second Floor																			
FCU 201	Room 3006	430	70	Direct	1	10.8	8.9	75.98	57.3	R410A	14.7	66.74	97.3	3/16" Washable	208/1	2.3	ARNU183M2A4	MAX. ESP =0.7	
FCU 202	Room 3005	600	370	Direct	1	16.9	13.5	78.70	53.3	R410A	22.7	57.67	101.1	3/16" Washable	208/1	2.3	ARNU243M2A4	MAX. ESP =0.7	
FCU 203	Room 3002	660	330	Direct	1	22.2	17.8	78.00	53.2	R410A	29.9	60.00	101.7	3/16" Washable	208/1	2.3	ARNU243M2A4	MAX. ESP =0.7	
FCU 204	Room 3003	430	200	Direct	1	15	11.9	77.79	53.9	R410A	19.5	60.70	100.9	3/16" Washable	208/1	2.3	ARNU243M2A4	MAX. ESP =0.7	
FCU 205	Room 3014	640	170	Direct	1	20.6	16.8	76.59	52.4	R410A	28.3	64.69	105.5	3/16" Washable	208/1	2.3	ARNU243M2A4	MAX. ESP =0.7	
FCU 206	Room 3015	660	210	Direct	1	22.2	17.8	76.91	53.2	R410A	29.9	63.64	101.7	3/16" Washable	208/1	2.5	ARNU243M2A4	MAX. ESP =0.7	
FCU 207	Room 3016	1450	310	Direct	1	30.7	35.1	76.28	62.4	R410A	40.9	65.72	85.1	3/16" Washable	208/1	2.5	ARNU283M3A4	MAX. ESP =0.7	
FCU 208A	Room 3017	800	260	Direct	1	20.1	13.6	76.95	61.9	R410A	24.9	63.50	90.1	3/16" Washable	208/1	2.3	ARNU183M2A4	MAX. ESP =0.7	
FCU 208B	Room 3017	800	260	Direct	1	20.1	13.6	76.95	61.9	R410A	24.9	63.50	90.1	3/16" Washable	208/1	2.3	ARNU183M2A4	MAX. ESP =0.7	
FCU 209	Room 3018	320	60	Direct	1	10.8	8.9	76.13	57.3	R410A	14.7	66.25	97.3	3/16" Washable	208/1	2.3	ARNU183M2A4	MAX. ESP =0.7	
FCU 210	Room 3021	530	320	Direct	1	16.9	13.5	78.62	53.3	R410A	22.7	57.92	101.1	3/16" Washable	208/1	2.3	ARNU243M2A4	MAX. ESP =0.7	
FCU 211	Room 3025	430	100	Direct	1	10.8	8.9	76.40	57.3	R410A	14.7	65.35	97.3	3/16" Washable	208/1	2.3	ARNU183M2A4	MAX. ESP =0.7	
Third Floor																			
FCU 301	Room 4006	430	70	Direct	1	15.4	15.4	75.98	43.2	R410A	17.1	66.74	102.3	3/16" Washable	208/1	2.3	ARNU183M2A4	MAX. ESP =0.7	
FCU 302	Room 4005	600	270	Direct	1	22.7	22.7	77.70	36.2	R410A	25.2	61.00	105.7	3/16" Washable	208/1	2.3	ARNU243M2A4	MAX. ESP =0.7	
FCU 303	Room 4002	340	120	Direct	1	12.9	12.9	77.12	42.2	R410A	14.3	62.94	101.2	3/16" Washable	208/1	2.3	ARNU153M2A4	MAX. ESP =0.7	
FCU 304	Room 4003	430	200	Direct	1	19.6	19.6	77.79	37.4	R410A	21.7	60.70	105.5	3/16" Washable	208/1	2.3	ARNU243M2A4	MAX. ESP =0.7	
FCU 305	Room 4026	430	130	Direct	1	19.6	19.6	76.81	34.8	R410A	21.7	63.95	110.5	3/16" Washable	208/1	2.3	ARNU243M2A4	MAX. ESP =0.7	
FCU 306	Room 4014	570	160	Direct	1	25.9	24.9	76.68	36.4	R410A	28.7	64.39	110.9	3/16" Washable	208/1	2.3	ARNU243M2A4	MAX. ESP =0.7	
FCU 307	Room 4017	500	270	Direct	1	22.7	22.7	78.24	36.3	R410A	25.2	59.20	105.7	3/16" Washable	208/1	2.3	ARNU243M2A4	MAX. ESP =0.7	
FCU 308	Room 4021	320	70	Direct	1	15.4	15.4	76.31	43.2	R410A	17.1	65.63	102.3	3/16" Washable	208/1	2.3	ARNU183M2A4	MAX. ESP =0.7	