
<u>GENERAL CONTRACTOR'S RESPONSIBILITIES:</u> a. Read Cylon Retail Solutions (CRS) / Dollar Tree (DT) Documentation Package.

b. Review all DT drawings.

 Contact Cylon Retail Solutions Inc. at (888) 211-6789 and submit a fully completed EMS Installation Survey.
 Confirm CRS Survey Form is fully completed and EMAILED to CRS National Account Team at <u>Surveys@Cylon.com</u> or FAXED to (855) 224-0879, <u>24 Hours Prior to scheduling the EMS</u> Commissioning.
 EMS Commissioning dates cannot be scheduled until fully completed EMS Installation Surveys have been received and approved by the CRS National Deployment Team. c. Schedule remote EMS commissioning <u>24 hours prior</u> to the requested commissioning date.

II. ELECTRICAL RESPONSIBILITIES: Power to all EMS equipment and devices must be OFF while terminations are made a. Provide all labor and installation material, as required, for a complete and operational EMS for this DT store location. b. Receive and store all CRS material in a dry and secure place until the EMS installation is completed.
c. The EMS equipment will be supplied by CRS and installed by an approved DT contractor. d. Review the entire set of plans, perform a job site survey and inventory the CRS equipment to ensure the proper equipment has been ordered and received for a complete and operational CRS EMS. e. If any material is missing or additional equipment is required, immediately call CRS at (888) 211-6789 to request an order. f. Approved Contractor shall verify number of controlled lighting circuits against the design, report discrepancies, which cannot be resolved in the field, to the CRS National Account Support Team at (888) 211-6789 and wait for resolution instructions. g. Coordinate the EMS installation with the Mechanical Contractor to avoid any interference that may delay progress during construction. h. Perform all work in accordance with all National, State and Local Codes for this project i. All EMS cables are to be installed per National and Local Codes. It is the Electrical Contractor's responsibility to determine if National and Local Codes permit Class 2 cables to be installed exposed within the building structure or if a full conduit system is required. j. EMT connectors and bushings are to be installed at the top of every conduit sleeve and threaded connector to protect EMS cables from abrasions. k. All cables are to be clearly and distinctly labeled within one foot of both ends. I. Furnish and install all required conduit, boxes, wire ways, fittings, straps, hangers and wiring for a complete and operational EMS as required. m.Furnish and install a dedicated 120 VAC circuit with breaker lock for the EMS Panel. i. Label breaker: DO NOT TURN OFF / EMS ii. Confirm wiring is completed as per this documentation package before applying power. Improper wiring will cause damage to equipment. n. Mount the EMS Panel adjacent to the electrical panels. o. Install an Ethernet cable run from the eSCi RJ-45 jack located in the EMS Panel to the network switch specified by the DT networking team. p. Call CRS at 888.211.6789 to verify Network Connectivity before proceeding with the EMS installation.
q. Install and terminate the CRS BACnet communication trunk, in a daisy chain fashion, from the EMS Panel to each of the Thermostat Controls and all other BACnet devices. (see this documentation package for requirements)
r. When applicable, mount the Auxiliary I/O Panel adjacent to the EMS Panel and ensure both panels are connected to the same Earth Ground.
s. When applicable, ensure the Auxiliary I/O panel is connected in series with the other BACnet devices on the BACnet communications trunk. t. Mount and terminate the Outdoor Sensor Assembly (OSA) on the HVAC unit that resides closest to the EMS Panel. When installing, make sure OSA enclosure is: i. Mounted on a 1" rigid riser with an 'LB' secured to the back of the OSA (Refer to OTS/OLS Detail as shown on EM-4) ii. Mounted 3 feet above the HVAC unit iii. Mounted facing north, away from the combustion heat blower and condenser fan iv. Weather-proofed v. Mounted with the white PVC sensor pointed downward vi.Positioned to allow the Outdoor Light Sensor exposure to full ambient daylight but is not shadowed or exposed to any artificial illumination u. When applicable, mount and terminate the CO2 Sensor as per the location specified by the DT drawings and this documentation package. v. Mount and terminate the Override Button assembly as per the location specified by the DT drawings and this documentation package. w. Do not adjust the DIP Switches for the EMS Override Buttons. They are factory preset for: i. MSTP Address = 35 ii. Baud Rate = 19200 iii. Network Termination = Off x. When applicable, mount and terminate the Indoor Ambient Light Sensor(s) as per the location specified by the DT drawings and the Special Instructions in this documentation package. y. Install and wire load sides of lighting contactors for designated lighting loads and zones as required by DT and this documentation package Employee Zone = 40% of Sales floor and 100% of all Stockroom areas Customer Zone = Remaining 60% of Sales Floor iii. Exterior Zone = Building Exterior and Parking lights iv. When applicable, Daylight Zone = First two (2) rows of lights along the store-front windows. z. Furnish and install a 3-pole, 20-amp breaker/disconnect at the Main Electrical Distribution Panel (MDP) for the Phase Loss Power Monitor and Energy Meter. aa. When applicable, furnish and install a 3-pole, 20-amp breaker/disconnect at each Electrical Distribution Panel for each additional Phase Loss Power Monitor bb.Terminate wiring as specified in this documentation package. i. Label Main Electrical Distribution Panel breaker/disconnect: DO NOT TURN OFF / PHASE FAILURE & ENERGY METER ii. When applicable, label auxiliary Electrical Distribution Panel breaker/disconnect: DO NOT TURN OFF / PHASE FAILURE iii. Confirm wiring is completed as per this documentation package before applying power. Improper wiring will cause damage to equipment. cc. Install and terminate the CRS Modbus communication trunk from the eSCi Controller to the Energy Meter. (Refer to OEM instructions and this documentation package for requirements) dd.Permanently mount and terminate the Electrical Meter in close proximity to the main utility power feed. ee.Permanently mount the 3 Current Sensors, one each, around the 3 phases of the main utility feed. ff. Terminate the 3 Current Sensors to the Energy Meter, correctly maintaining Electrical Phase and Meter Input relationships. gg.Using the OEM Instructions, configure the EMS Energy Meter for: i. Proper Current Transformer (CT) Ratio - Current Sensor Primary (Ct) = 400 - 1500 Amp ii. Nominal Line to Line Voltage = 480 Vac iii. Baud Rate = 19200 iv. Address = 1 v. Voltage Input Mode = True 3 Phase vi.CT Auto Rotation = Auto Rotate Note: The EMS is designed to monitor a single primary 3 phase power feed. Contact CRS for support when attempting to monitor multiple power feeds hh.Provide a technician, on site, for an approximate 2-hour remote telephone checkout with CRS. ii. Coordinate with the Mechanical Contractor to verify HVAC control during the CRS remote telephone checkout.
jj. Prior to scheduling the Remote Commissioning Checkout, the Electrical Contractor will:
i. Confirm CRS Survey Form is completed and EMAILED to CRS National Account Team at <u>Surveys@Cylon.com</u> or FAXED to (855) 224-0879, <u>24 Hours Prior to scheduling the EMS Commissioning</u>.
ii. Confirm the Mechanical Contractor will be present during the CRS Remote Commissioning Checkout. iii. Contact CRS to schedule the EMS Commissioning, 24 hours prior at (888) 211-6789. III. MECHANICAL RESPONSIBILITIES: Power to all EMS equipment and devices must be OFF while terminations are made. a. Provide labor and installation material, as required, for a complete and operational EMS for this DT store location. b. Verify number and type of HVAC units against the design, report discrepancies, which cannot be resolved in the field, to the CRS National Account Support Team at (888) 211-6789 and wait for resolution instructions. c. Perform all work in accordance with all National, State and Local Codes for this project. d. Mount and terminate the SimpleSTAT module(s) as per the location(s) specified by the DT drawings and this documentation package. e. Utilizing 18/8 cable between the SimpleSTAT module and HVAC unit. i. Terminate C, R, G, Y1, Y2, W1 and W2 on the HVAC unit for control of fan, cooling and heating.
 ii. Terminate the communications cables to the SimpleSTAT(s) as shown in this documentation package.
 f. Set address on the SimpleSTAT module, as shown in the SimpleSTAT installation instructions. When communications to the EMS is in a failed state, the SimpleSTAT will operate 24/7 as a stand-alone STAT using the following temperature setpoints: i. Default Cooling Setpoint = 72.0 °F ii. Default Heating Setpoint = 68.0 °F g. Utilizing the Downrods and associated hardware, specified by the DT drawings and the "Special Instructions" section of this documentation package, mount and terminate the Remote Space Temperature Sensor(s) as per the location(s) specified by the DT drawings. i. In close proximity to the zone return air grille and away from supply air drafts. ii. Install and secure the Remote Temperature Sensor wire to the Thermostat Controller. h. Mount the Supply Duct Temperature sensor of each HVAC unit. i. The remote Supply Duct Temperature Sensor should be mounted in the main Supply Air Duct on the interior side of the HVAC unit's building penetration. ii. Utilizing 18/2 wire, terminate the supply duct temperature sensor wire to the Thermostat module as shown in this documentation package. i. Provide Electrical Contractor with roof plan layout, showing location of HVAC Units on the roof. Provide a technician, on site, for an approximate 2-hour remote telephone checkout with CRS. k. Coordinate with the Electrical Contractor to verify proper HVAC control during the CRS Remote Commissioning Checkout. IV. CYLON RETAIL SOLUTIONS RESPONSIBILITIES a. The following services will be supplied by CRS: i. Shipping of all contracted EMS components for the job.
ii. Programming and downloading of CRS equipment and software.
iii. Provide telephone technical support at (888) 211-6789. iv. Remote system checkout with installing contractor b. Verification of proper operation of the following items by exercising the controlled load:
i. Timed operation of all applicable EMS lighting loads - Interior and Exterior.
ii. Outside light level control of all applicable EMS lighting loads - Interior and Exterior.
iii. Operation of HVAC heating stages, as indoor environment allows. iv. Operation of HVAC cooling stages, as indoor and outdoor environments allow. v. Verification of HVAC unit sensor readings - space and supply temperatures. c. If any end unit (e.g. lighting, HVAC unit, supply air fan, etc.) cannot be operated for mechanical or electrical reasons, CRS will verify the proper operation of the EMS control devices (e.g. contactors, discrete I/O) leading up to the unit, in order to fully verify the operations of the d. CRS will issue an "EMS Check-Out Number" once all store systems are verified as operational.

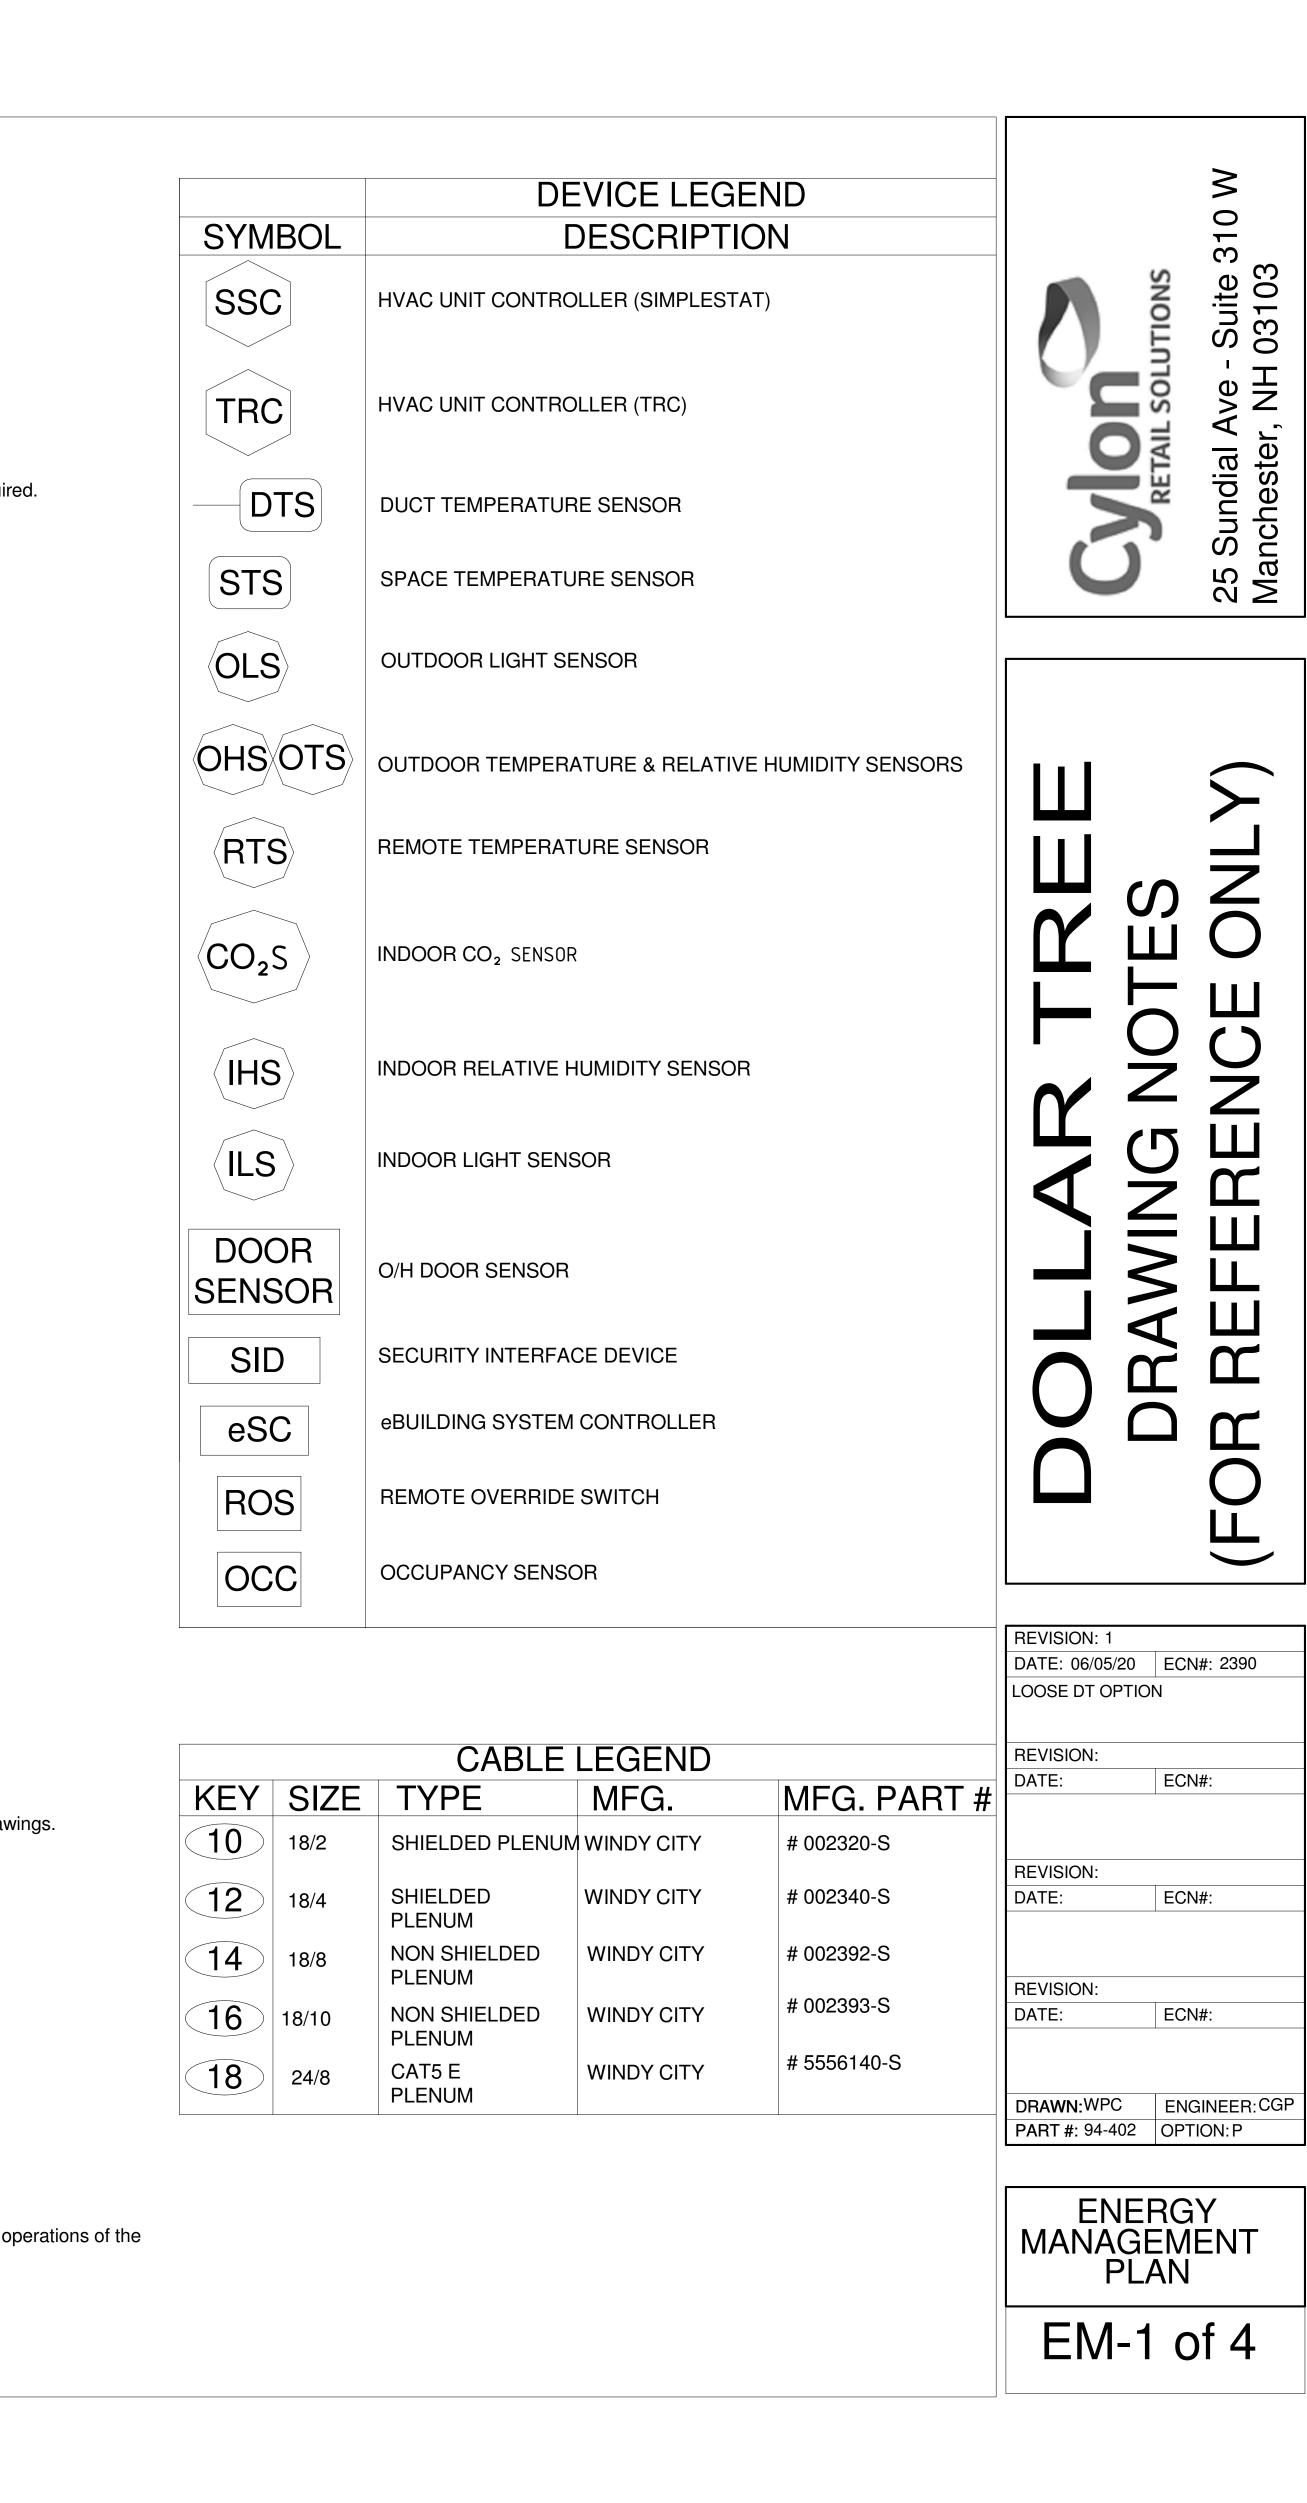

KEY	SIZE	TYPE	MFG.	MFG. PART #	DATE.	
(10)	18/2	SHIELDED PLENUM	WINDY CITY	# 002320-S		
					REVISION:	
12	18/4	SHIELDED PLENUM	WINDY CITY	# 002340-S	DATE:	ECI
14	18/8	NON SHIELDED PLENUM	WINDY CITY	# 002392-S		
		_		# 002393-S	REVISION:	
(16)	18/10	NON SHIELDED PLENUM	WINDY CITY	# 002393-3	DATE:	ECI
18	24/8	CAT5 E PLENUM	WINDY CITY	# 5556140-S		
					DRAWN:WPC	EN
					DADT // 04 400	

