NEW PANEL.

2 THIRD FLOOR BAR 1/4" = 1'-0"

ELECTRICAL SHEET NOTES - FOOD SERVICE

- COORDINATE ALL EQUIPMENT OUTLET CONNECTIONS WITH KITCHEN EQUIPMENT CONTRACTOR PRIOR TO ROUGHING.
- ALL EQUIPMENT CONNECTIONS SHALL BE PROVIDED WITH LIQUIDTIGHT FLEXIBLE
- ALL RECEPTACLES ON BUILDING WALLS, AT COUNTER HEIGHT, SHALL BE MOUNTED HORIZONTALLY, UNLESS NOTED OTHERWISE.
- THE ELECTRICAL CONTRACTOR SHALL PROVIDE OCTAGONAL JUNCTION BOX AND 3/4" CONDUIT STUBBED ABOVE HUNG CEILING FOR INSTALLATION OF FIRE SUPPRESSION SYSTEM. REMOTE MANUAL PULL STATION BY KITCHEN EQUIPMENT CONTRACTOR. VERIFY EXACT LOCATION WITH FIRE AUTHORITIES. PROVIDE CONNECTION FROM FIRE SUPPRESSION SYSTEM TO FIRE ALARM CONTROL PANEL AND ALL REQUIRED RELAYS TO ACTIVATE FIRE ALARM SYSTEM UPON ACTIVATION OF FIRE SUPPRESSION. SYSTEM.
- VERIFY EXACT MOUNTING HEIGHT FOR ALL OUTLET CONNECTIONS WITH KITCHEN EQUIPMENTS CONTRACTOR, EQUIPMENT MANUFACTURER AND/OR ARCHITECT.
- DISCONNECT SWITCHES, MOTOR STARTERS OR OTHER DEVICES (EXCEPT FOR RECEPTACLES OR JUNCTION BOX CONNECTIONS) SHALL NOT BE LOCATED BEHIND KITCHEN EQUIPMENT OR BELOW EXHAUST HOOD ASSEMBLIES.
- EQUIPMENT LOCATED BELOW EXHAUST HOOD ASSEMBLIES. SHUNT-TRIP CIRCUIT BREAKERS SHALL BE CONNECTED TO RESPECTIVE FIRE PROTECTION SYSTEM TO SHUT DOWN EQUIPMENT UPON ACTIVATION OF FIRE PROTECTION SYSTEM. THE ELECTRICAL CONTRACTOR SHALL PROVIDE WIRING FOR THE FOLLOWING AT ALL EXHAUST HOOD AND VENTILATOR LOCATIONS:

THE ELECTRICAL CONTRACTOR SHALL PROVIDE SHUNT-TRIP CIRCUIT BREAKERS FOR ALL


- a.BRANCH CIRCUIT WIRING TO CONTROL PANEL. b.CONTROL WIRING FROM CONTROL PANEL TO EACH HOOD SECTION FOR DAMPERS, SOLENOIDS AND LIGHTS.

 c.CONTROL WIRING FROM CONTROL PANEL TO SUPPLY AND EXHAUST FANS. d.FIRE SYSTEMS CONTROL WIRING BETWEEN FIRE SUPPRESSION SYSTEM, CONTROL
- e.CONTROL WIRING FROM CONTROL PANEL TO REMOTE DETERGENT PUMPS. f.COORDINATE ALL SPECIFIC REQUIREMENTS WITH THE KITCHEN EQUIPMENT CONTRACTOR.

ALL 15 AND 20 AMPERE, 125 VOLT RECEPTACLES WITHIN KITCHEN AREA SHALL BE GFCI

- PROTECTED BY RECEPTACLE OR BREAKERS. CONTRACTOR SHALL PROVIDE DISCONNECT SWITCHES IN ACCORDANCE WITH ALL APPLICABLE LOCAL CODES. ALL DISCONNECT SWITCHES IN DISH WASHING, COOKING AND SERVERY AREAS SHALL BE NEMA TYPE 3R. DISCONNECTS SHALL BE WALL MOUNTED AND LOCATED TO AVOID THE SPLASHING OF WATER.
- LOCATE JUNCTION BOX FOR WALK-IN REFRIGERATION EQUIPMENT AT CEILING OF UNIT. ROUTE CONDUIT TO JUNCTION BOX AT DOOR PANEL INSIDE UNIT FOR CONNECTION OF LIGHTS, DOOR HEATERS, ETC.
- FIELD WIRING BETWEEN THE CONDENSING UNIT, THE EVAPORATOR COIL AND RELATED COMPONENTS SHALL BE PROVIDED BY THE ELECTRICAL CONTRACTOR. PROVIDE 6#12 IN A 3/4" CONDUIT FROM THE REMOTE CONDENSING UNIT TO THE EVAPORATOR COIL THERMOSTAT AND SOLENOID VALVE CONTROL WIRING. (THERMOSTAT & SOLENOID BY
- REFER TO FOOD SERVICE DRAWINGS FOR DEVICE TYPES.

PANELS AND REMOTE FIRE CONTROL SHUT-OFFS.

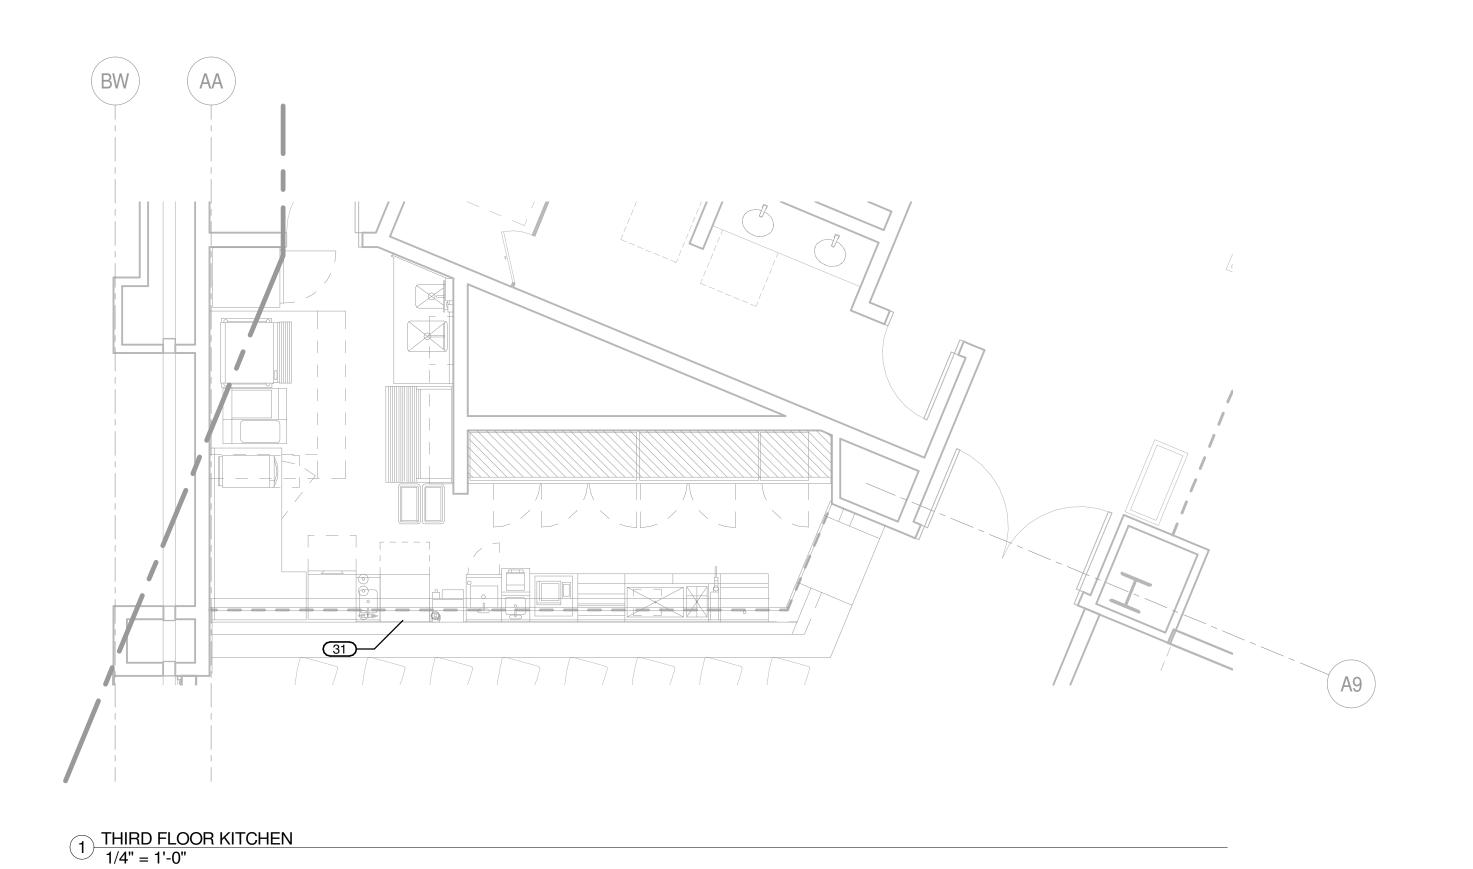

| | FOOD SERVICE DEVICE LEGEND | | | | | | | | | |
|--------|--|--|--|--|--|--|--|--|--|--|
| СР | CONTROL PANEL | | | | | | | | | |
| DC | DROP CORD | | | | | | | | | |
| DR-15 | DUPLEX RECEPTACLE - 15A | | | | | | | | | |
| DR-20 | DUPLEX RECEPTACLE - 20A | | | | | | | | | |
| DS | DISCONNECT SWITCH | | | | | | | | | |
| FDS | FUSED DISCONNECT SWITCH | | | | | | | | | |
| JB | JUNCTION BOX | | | | | | | | | |
| PB | PULL BOX | | | | | | | | | |
| QDR-15 | DOUBLE DUPLEX RECEPTACLE - 15A | | | | | | | | | |
| QDR-20 | DOUBLE DUPLEX RECEPTACLE - 20A | | | | | | | | | |
| SR-* | SPECIAL PURPOSE RECEPTACLE, ASTERISK DENOTES A SYMBOL NUMBER PER SPECIAL PURPOSE RECEPTACLE SCHEDULE ON DRAWING E-601. | | | | | | | | | |

| # | ELECTRICAL FOOD SERVICE SCHEDULE | | | | | | | | | | | | | |
|--------|------------------------------------|---------|---|------|------|--------|---------|-----------------------------|-----------|---------|---|--|--|--|
| ITEM # | DESCRIPTION | VOLTAGE | Ф | AMPS | kVA | DEVICE | BREAKER | WIRE & CONDUIT | PANEL | CIRCUIT | REMARKS | | | |
| | | | | | | | | | | | | | | |
| 1 | P.O.S. STATION | 120 | 1 | 5 | 0.6 | DR-15 | 15A-1P | SEE BRANCH CIRCUIT SCHEDULE | LNK3-9-1A | 4 | | | | |
| 1 | P.O.S. STATION | 120 | 1 | 5 | 0.6 | DR-15 | 15A-1P | SEE BRANCH CIRCUIT SCHEDULE | LNK3-9-1A | 7 | | | | |
| 2 | P.O.S. CHECK PRINTER | 120 | 1 | 5 | 0.6 | DR-15 | 15A-1P | SEE BRANCH CIRCUIT SCHEDULE | LNK3-9-1A | 3 | | | | |
| 2 | P.O.S. CHECK PRINTER | 120 | 1 | 5 | 0.6 | DR-15 | 15A-1P | SEE BRANCH CIRCUIT SCHEDULE | LNK3-9-1A | 6 | | | | |
| 9 | WINE COOLER | 120 | 1 | 2 | 0.26 | DR-15 | 15A-1P | SEE BRANCH CIRCUIT SCHEDULE | LNK3-9-1A | 8 | | | | |
| 9 | WINE COOLER | 120 | 1 | 2 | 0.26 | DR-15 | 15A-1P | SEE BRANCH CIRCUIT SCHEDULE | | | EXISTING DEVICE TO REMAIN | | | |
| 12 | WINE DISPENSING SYSTEM | 120 | 1 | 2 | 0.24 | DR-15 | 15A-1P | SEE BRANCH CIRCUIT SCHEDULE | LNK3-9-1A | 9 | | | | |
| 12 | WINE DISPENSING SYSTEM | 120 | 1 | 2 | 0.24 | DR-15 | 15A-1P | SEE BRANCH CIRCUIT SCHEDULE | | | EXISTING DEVICE TO REMAIN | | | |
| 13 | BACK BAR EQUIPMENT | 120 | 1 | 2 | 0.22 | DR-15 | 15A-1P | SEE BRANCH CIRCUIT SCHEDULE | LNK3-9-1A | 10 | | | | |
| 13 | BACK BAR EQUIPMENT | 120 | 1 | 2 | 0.22 | DR-15 | 15A-1P | SEE BRANCH CIRCUIT SCHEDULE | | | EXISTING DEVICE TO REMAIN | | | |
| 14 | SPHERE ICE MACHINE | 120 | 1 | 5 | 0.6 | JB | 15A-1P | SEE BRANCH CIRCUIT SCHEDULE | LNK3-9-1A | 5 | | | | |
| 21 | ICE MACHINE | 208 | 1 | 2 | 0.42 | JB | 20A-2P* | SEE BRANCH CIRCUIT SCHEDULE | LNK3-9-1 | 39,41 | SERVED FROM BREAKER FREED UP FROM DEMOLITION | | | |
| 22 | REFRIGERATOR, REACH-IN, GLASS DOOR | 120 | 1 | 4 | 0.46 | DR-15 | 15A-1P | SEE BRANCH CIRCUIT SCHEDULE | LNK3-9-1A | 11 | | | | |
| 22A | DROP DOWN CORD REEL | 120 | 1 | 15 | 1.8 | DR-15 | 15A-1P | SEE BRANCH CIRCUIT SCHEDULE | | | FED FROM ITEM 22 | | | |
| 31 | SPHERE ICE MACHINE | 120 | 1 | 5 | 0.6 | JB | 15A-1P | SEE BRANCH CIRCUIT SCHEDULE | LNK3-9-1A | 12 | | | | |

CROCKFORDS-RESORTS WORLD CATSKILLS

888 resorts World Dr Monticello, NY 12701


JCJARCHITECTURE 120 HUYSHOPE AVENUE

SUITE 400 HARTFORD, CT 06106 860.247.9226

© 2021 JCJ Architecture

CONSULTANT: R.G. Vanderweil Engineers, LLP 617.423.7423 TEL 274 Summer Street 617.423.7401 FAX : Boston, MA 02210 : vanderweil.com

BIDDING & CONSTRUCTION 07/06/2022

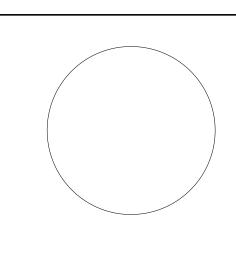

JOB 30860.00

DRAWN_JDB

SCALE ___1/4" = 1'-0" REVISIONS

ELECTRICAL ENLARGED KITCHEN