GENERAL NOTES:

- ALL MILLWORK AND HARDWARE TO BE SUPPLIED AND INSTALLED BY GC. ALL MILLWORK TO BE STAINED TO MATCH RTA ESPRESSO AND APPROVED SAMPLE BY OWNER VIA SUBMITTAL
- 2. ALL MILLWORK TO BE WOOD VENEER OVER MDF. INTERIOR TO BE OAK COLORED MELAMINE OVER MDF.
- 3. ALL LAMINATE COUNTERTOPS TO HAVE CHAMFERED EDGES
- PROVIDE CLEAR SILICONE BUMPERS ON WALLS ADJACENT TO CABINET DOORS FOR PROTECTION FROM DOOR HARDWARE FRAMES TO BE SECURED TO WALL WITH GRK T-10 FIN/TRIM HEAD SCREWS @ EACH CORNER
- 6. ALL EXPOSED AREAS OF MILLWORK TO HAVE FINISHED ENDS
- GC TO INSTALL ALL DECOR PROVIDED BY OWNER.
 UPPER CABINETS TO HAVE 2 INTERIOR SHELVES, BASE CABINETS 1 SHELF
- SINK BASE CABINETS TO BE EXTERIOR GRADE PLYWOOD W/WOOD VENEER FINISHED ENDS MATCH STAIN AT AREAS OF WALL PANELLING, RAISE PANELLING TO ALLOW SPACE FOR VINYL BASE TO BE INSTALLED TO GYP BOARD

NOTE: SEE SHEET E-200 - POWER PLAN - FOR ADDITIONAL INFORMATION ON POWER/DATA REQUIREMENTS.



WAITING ROOM - SIM

 SHELF FOR PC FOR PAINT GYP. BD - VINYL FENCE PROVIDED DIGITAL SIGNAGE - GC **CEILING PT4** & INSTALLED BY GC, TYP. TO SUPPLY & INSTALL GROMMET PNL3 PAINT ALL SIDES OF OPENING PT2, TYP. PNL3 CLEAR ACRYLIC - CLEAR AGRYLIC PANEL PAINT ALL SIDES OF PANELS -OPENING PT2, TYP. -PAINT ALL SIDES OF OPENING PT2, TYP. BULLN**O**SE EDGE PAPER SHREDDER OWNER PROVIDED, GROMMETS ABOVE GC INSTALLED. — EVERY OUTLET, TYP. PEDESTAL CABINET GC CASH DRAWERS GC COUNTER SUPPORT BRACKET - SAFE GC SUPPLIED PEDESTAL CABINET GC RAKKS #EH18-18, ANODIZED ALUM. INSTALL PER MANF. RECOMMENDATIONS, TYP SUPPLIED & INSTALLED. FINISHED ENDS, TYP. SUPPLIED & INSTALLED. FINISHED ENDS, TYP. — SUPPLIED & INSTALLED -& INSTALLED

2 WAITING ROOM ELEV A

1/2" = 1'-0"

1 FRONT RECEPTION WALL

TYP PT1

PNL1 TYP

MURAL PROVIDED BY OWNER INSTALLED BY GC

CENTER ON WALL -

WRAP PT2 AT RETURN

1/2" = 1'-0"

3 WAITING ROOM ELEV C

_GC SUPPLIED & _

INSTALL TV TO

COVER OUTLETS

PROVIDE BLOCKING

PAINT WALL PT2 AT RETURN

INSTALLED TV & BRACKET


TYP. PT1


PNL1

EQ_

00000

4 RECEPTION DESK ELEV

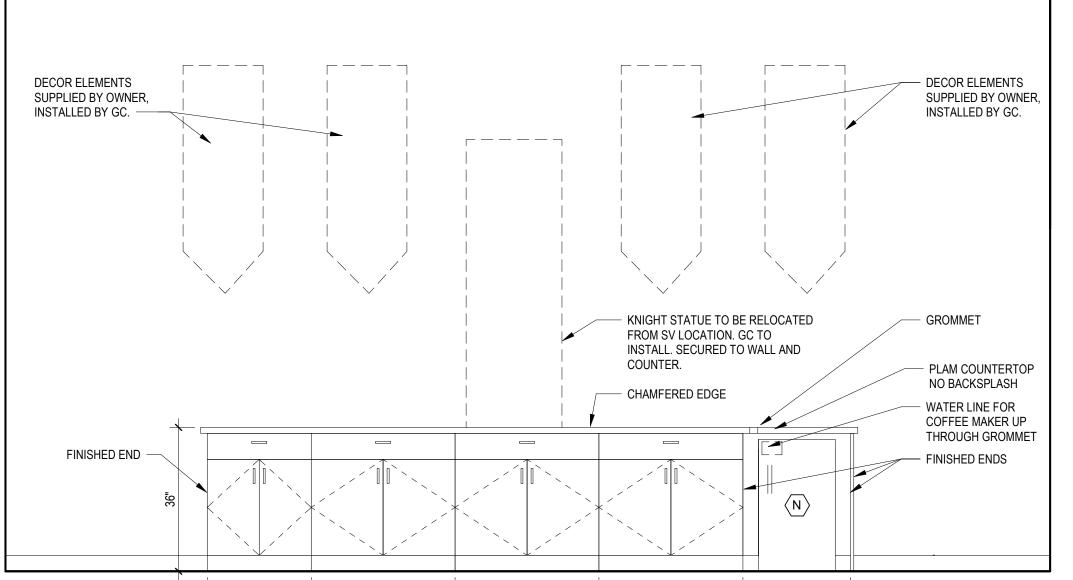

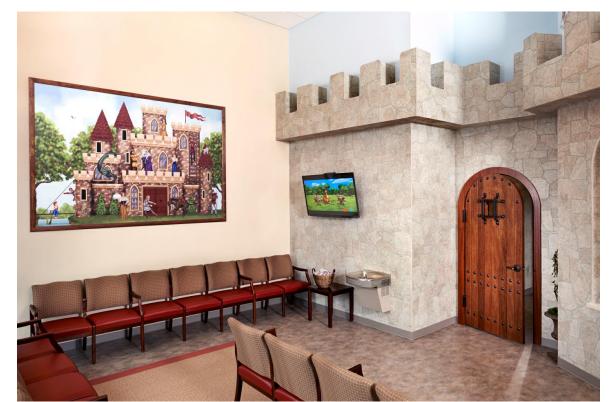



WAITING ROOM - SIM WAITING ROOM - SIM

A-203

INTERIOR ELEVATIONS

M PEDIATRICS HOPS @ NANUET SASHION DR.

Design and construction documents as instruments of service are given in confidence and remain the property of Onyx Creative. The use of this design and these

construction documents for purposed other than the specific project named herein is strictly prohibited without expressed written

consent of Onyx Creative.

Project No.: 20251

Drawn By: MES

Date Issue
8-31-23 LANDLORD REVIEW

12-05-23 1 RFI RESPONSES

5 RECEPTION - REAR WALL

1/2" = 1'-0"