

GENERAL NOTES

- A. THE INTENT OF THESE ELEVATIONS IS TO SHOW LOCATIONS OF MAJOR INTERIOR ELEMENTS. ELEVATIONS MAY NOT SHOW ALL ITEMS IN ALL ROOMS.
- B. SEE INTERIOR DETAILS FOR ADDITIONAL CASEWORK INFORMATION.
- C. CASEWORK SHALL HAVE A 4" BACKSPLASH AND/OR SIDESPLASH AND 4" TOE KICK UNLESS NOTED OTHERWISE (U.N.O.).
- D. WALL CABINETS 24" HIGH SHALL HAVE ONE ADJUSTABLE SHELF. WALL CABINETS 25"-36" HIGH SHALL HAVE TWO ADJUSTABLE SHELVES UNLESS INDICATED OTHERWISE ON ELEVATIONS.
- E. BASE CABINETS SHALL HAVE ADJUSTABLE SHELVES AS INDICATED ON ELEVATIONS AND DETAILS (MINIMUM OF ONE SHELF).
- F. CABINET SHELVING SHALL BE FULL DEPTH. DRAWER BOXES SHALL BE FULL HEIGHT. PROVIDE MAXIMUM DRAWER BOX DEPTH AVAILABLE.
- G. INSTALL CHAIN STOPS IN ALL LOCATIONS WHERE CABINET DOOR IS ADJACENT TO A WALL OR OTHER OBSTRUCTION.
- H. INSTALL FILLER PANELS WHERE REQUIRED. INSTALL FILLER PANEL AT WALL JUNCTURE TO ALLOW DOORS TO OPEN COMPLETELY (MINIMUM 100 DEGREES) IF REQUIRED BY CABINET CONSTRUCTION.
- I. BASE AND TALL CABINETS SHALL BE 3/4" DEEP U.N.O. WALL CABINETS SHALL BE 1/2" DEEP U.N.O.
- J. INSTALL HEAVY-DUTY WORKSURFACE SUPPORT BRACKETS AS REQUIRED TO FULLY SUPPORT WORKSURFACE. BRACKETS SHALL BE METAL WITH W/REWAY OPENING (ASM HARDWARE WORK STATION OR HYBRID BRACKETS OR EQUAL). COLOR TO BE SELECTED BY ARCHITECT FROM MANUFACTURER'S FULL RANGE.
- K. INSTALL GROMMETS IN WORKSURFACES FOR ACCESS TO ELECTRIC AND DATA OUTLETS. COLOR TO BE SELECTED BY ARCHITECT FROM MANUFACTURER'S FULL RANGE.
- L. ALL OUTSIDE CORNERS OF GYPSUM BOARD WALLS SHALL HAVE A CORNER GUARD U.N.O. CORNER GUARDS SHALL BE INSTALLED AT TOP OF BASE.
- M. LOCKER RUNS WITHOUT END WALL SHALL HAVE BOXED END PANELS. PROVIDE FILLER AT LOCKER/WALL JUNCTURE WHERE REQUIRED. COORDINATE WITH CASEWORK ABOVE WHERE OCCURS.

PLUMBING FIXTURE / ACCESSORY LEGEND:

| | |
|-------|-----------------------------------|
| CS-1 | COUNTERTOP SINK |
| EWC-1 | DRINKING FOUNTAIN / BOTTLE FILLER |
| GB-1 | GRAB BAR, 36" |
| GB-2 | GRAB BAR, 42" |
| GB-3 | GRAB BAR, 18" |
| L-1 | LAVATORY |
| L-2 | ADA LAVATORY |
| M-1 | MIRROR 24"x36" |
| M-2 | MIRROR 18"x60" |
| MH-1 | MOP / BROOM HOLDER W/ SHELF |
| P-1 | TOILET PARTITION |
| PT-1 | PAPER TOWEL DISPENSER |
| PT-2 | PAPER TOWEL DISPOSAL UNIT |
| SD-1 | SOAP DISPENSER |
| SDU-1 | SANITARY DISPOSAL UNIT |
| SV-1 | SANITARY VENDOR |
| TP-1 | TOILET PAPER DISPENSER |
| U-1 | URINAL |
| UP-1 | URINAL PARTITION SCREEN |
| US-1 | UTILITY SINK |
| WC-1 | WATER CLOSET |

NOT FOR CONSTRUCTION

| | |
|-----------------|------------|
| DESIGNER | SR |
| PROJECT MANAGER | DL |
| DATE | 2022/05/04 |


USPS - MID-HUDSON, NY
 391 GOVERNOR DRIVE
 NEWBURGH, NY 12550





Facilities: 4301 Wilson Blvd., Suite 300, Arlington, VA 22203-1861

TYPICAL MOUNTING HEIGHTS


Scale: NTS
 Project: USPS - MID-HUDSON, NY
 USPS File Number: 35506-632

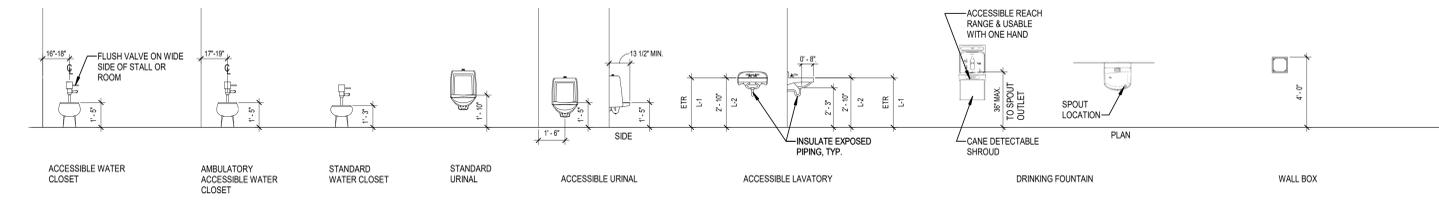


C1 TYPICAL PLUMBING FIXTURE MOUNTING HEIGHTS
 1/4" = 1'-0"

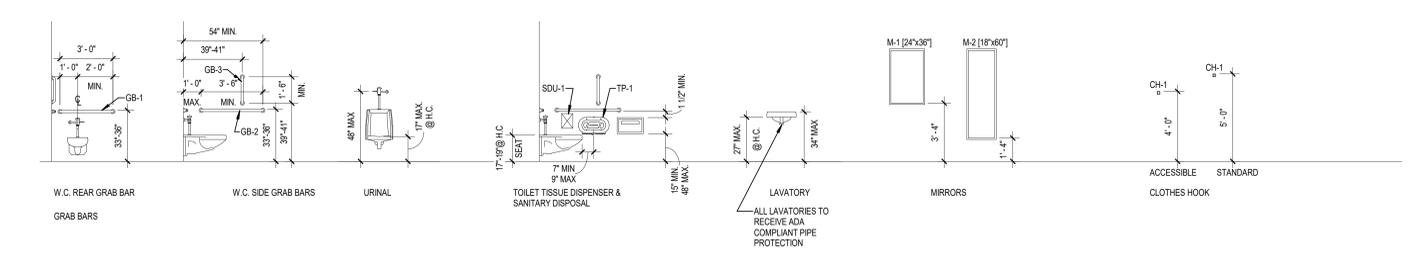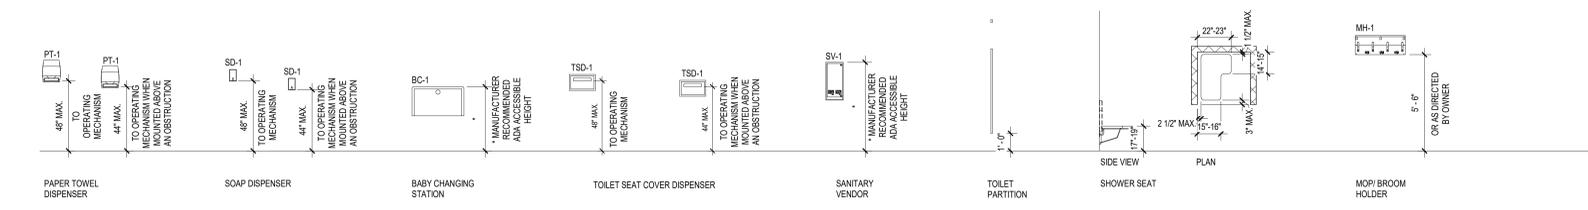

D1 TYPICAL TOILET ACCESSORY MOUNTING HEIGHTS
 1/4" = 1'-0"

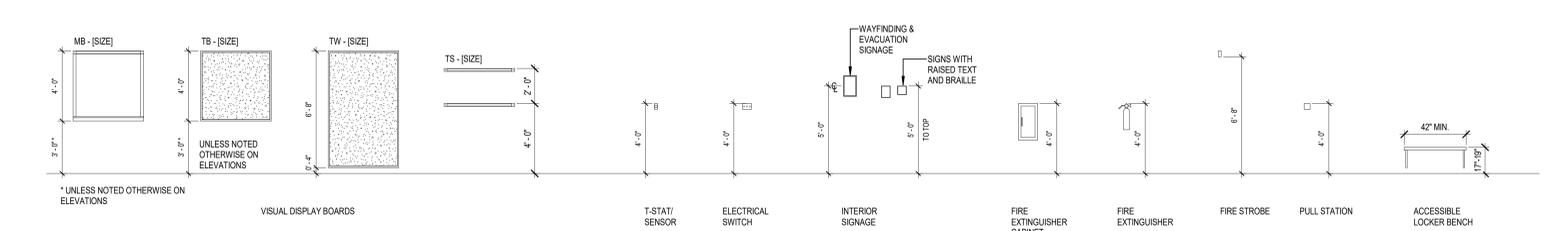

B1 TYPICAL MOUNTING HEIGHTS
 1/4" = 1'-0"

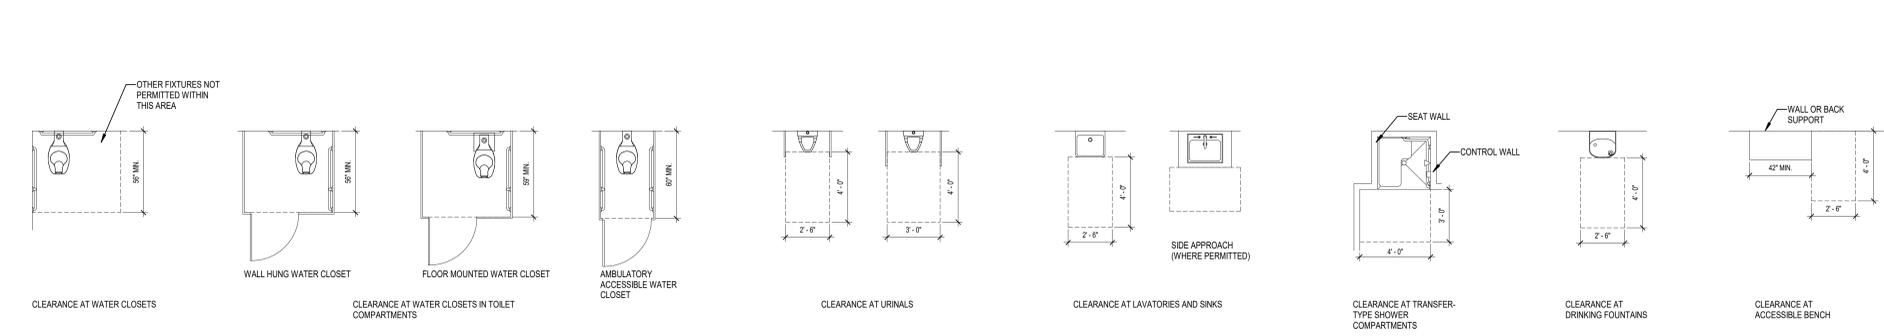

A1 ACCESSIBLE FIXTURE CLEARANCES
 1/4" = 1'-0"