



1 Smoke Detector Mounting Requirements

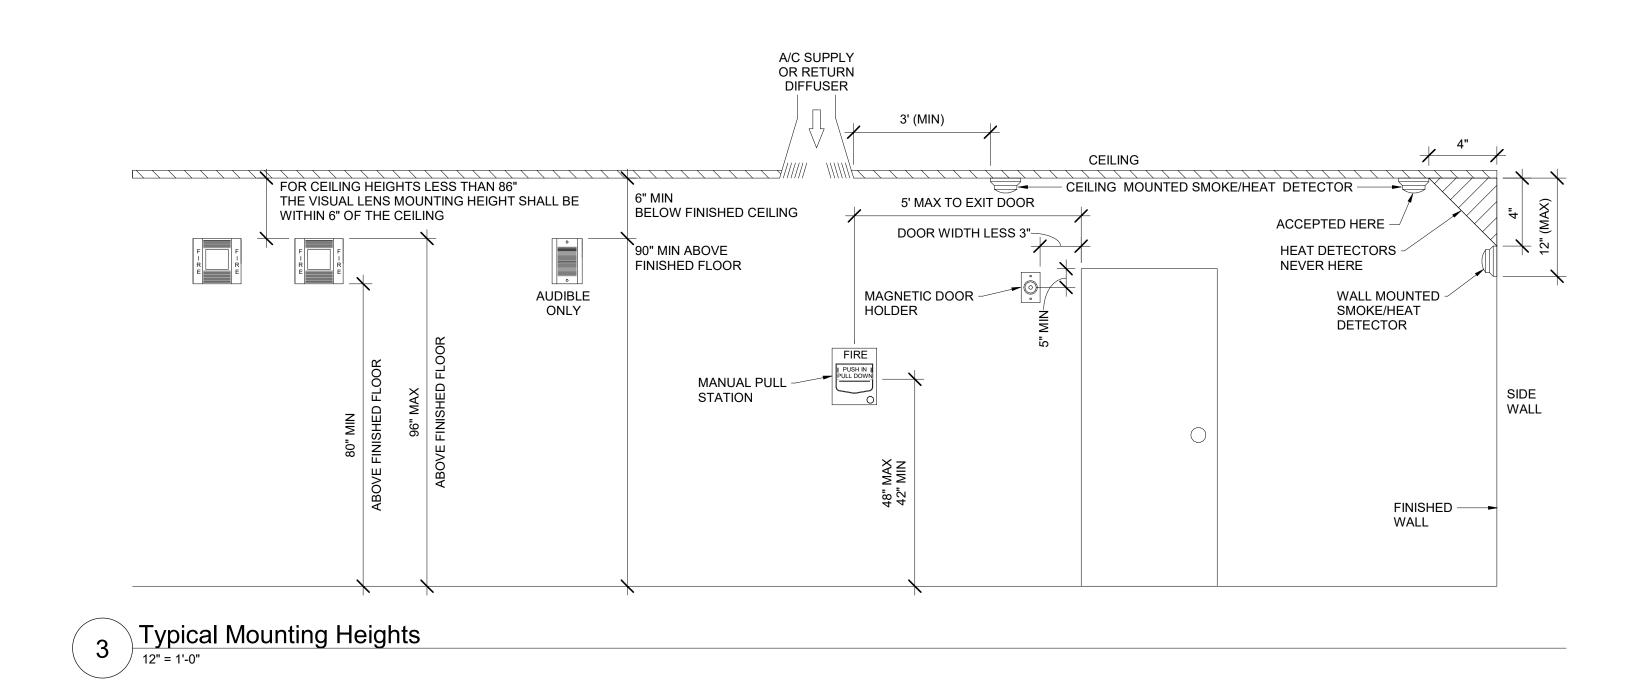

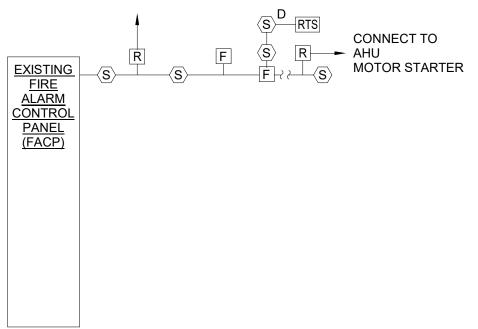


FIRE ALARM SEQUENCE OF OPERATION

- A. UPON ACTIVATION OF MANUAL PULL STATIONS, HEAT DETECTORS, SMOKE DETECTORS, DUCT DETECTORS. THE FIRE ALARM PANEL WILL GO INTO ALARM AND SHOULD SOUND THE A/V DEVICES, SHUT DOWN THE FANS, RELEASE THE MAGNETIC DOOR HOLDERS, CONTACT THE LOCAL FIRE DEPARTMENT AND INDICATE WHICH ALARM ZONE THE ALARM IS IN VIA THE REMOTE ANNUNCIATORS.
- B. UPON ACTIVATION OF A TROUBLE CONDITION THE FIRE ALARM PANEL SHALL GO INTO "TROUBLE" MODE INDICATING WHICH ZONE IS IN TROUBLE BY A LIGHT IN THE REMOTE ANNUNCIATOR AND AT THE FIRE ALARM PANEL.

NOTE:
FIRE ALARM RISER IS INTENDED TO BE SCHEMATIC ONLY.
ALL DEVICES INDICATED ON PLANS AND DETAILS ARE TO
BE INSTALLED AND CONNECTED FOR PROPER OPERATION

2 Fire Alarm System Wiring Diagram

12" = 1'-0"

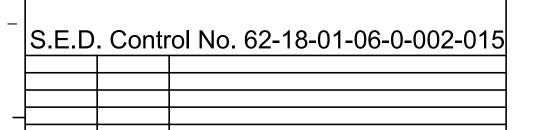

Rev. No.: Date: Description:

VALLKILL

CENTRAL SCHOOL DISTRICT





Wallkill Central School District Wallkill, New York

Reconstruction to:
John G. Borden Middle School

Details

Drawn By: Date: Drawing Number: Author 06/30/2023

Project No.:

Project No.: 17597-22002 BE500