Plumbing Fixture Schedule								
DWG LABEL	ROUGH-IN CONNECTION SIZE (INCHES)							
	SAN	VENT	CW	HW				
WC "C"	4	2	1	-				
WC "D"	4	2	1	-				
UR "A"	2	1 1/2	3/4	-				
UR "B"	2	1 1/2	3/4	-				
LAV "A"	1 1/2	1 1/2	1/2	1/2				
LAV "B"	1 1/2	1 1/2	1/2	1/2				
SHR "C"	-	-	1/2	1/2				
EWC "A"	1 1/2	1 1/2	1/2 -					
INT WH	-	-	3/4	-				
FD "A"	4	2	-	-				

NOTES:

1

2

4

5

6

7

8

9

10

11

REFER TO TOILET ROOM PLANS ON ARCHITECTURE DRAWINGS FOR FIXTURE CENTERLINE DIMENSIONS.

AGE GROUP	RIM HEIGHT	DESCRIPTION	NOTES
ADULT	15"	VITREOUS CHINA, WALL MOUNTED WITH SUPPORT, TOP SPUD, BATTERY OPERATED SENSOR FLUSH VALVE AND SEAT.	1, 2, 3
ADULT	17"	ACCESSIBLE, VITREOUS CHINA, WALL MOUNTED WITH SUPPORT, TOP SPUD, BATTERY OPERATED SENSOR FLUSH VALVE AND SEAT.	1, 2, 3
ADULT	24"	VITREOUS CHINA, WALL MOUNTED WITH SUPPORT, TOP SPUD AND BATTERY OPERATED SENSOR FLUSH VALVE.	1, 2, 3
ADULT	17"	ACCESSIBLE, VITREOUS CHINA, WALL MOUNTED WITH SUPPORT, TOP SPUD AND BATTERY OPERATED SENSOR FLUSH VALVE.	1, 2, 3
ADULT	31"	VITREOUS CHINA, WALL MOUNTED WITH SUPPORT, MANUAL, TWO-HANDLE COMMERCIAL FAUCET, SUPPLIES, TAILPIECE AND TRAP.	1, 2, 3
ADULT	34"	ACCESSIBLE, VITREOUS CHINA, WALL MOUNTED WITH SUPPORT, ACCESSIBLE, MANUAL, TWO-HANDLE COMMERCIAL FAUCET, SUPPLIES, OFFSET TAILPIECE AND VANDAL RESISTANT TRAP.	1, 2, 3
ADULT	-	ACCESSIBLE, FACTORY-FABRICATED, SURFACE MOUNTED SHOWER CABINET WITH VALVE ON RIGHT/ SEAT ON LEFT, SEVERE SERVICE HEAD, DIVERTER VALVE, HAND-HELD SHOWER SPRAY, RECESSED SOAP DISH, VERTICAL PIPING SHROUD AND VANDAL RESISTANT SCREWS.	1, 2, 3
ADULT	-	WALL MOUNTED, ACCESSIBLE, DUAL HEIGHT, PRESSURE WATER COOLER WITH FILTERED BOTTLE FILLING STATION .	1, 2, 3

MEDIUM DUTY, CAST-IRON FLOOR DRAIN WITH 7" DIAMETER NICKEL BRONZE STRAINER, DEEP-SEAL P-TRAP AND

1, 2

CONCEALED OUTLET, SELF DRAINING MODERATE CLIMATE WALL HYDRANT.

SIZES INDICATED ARE MINIMUM. LARGER SIZES SPECIFICALLY INDICATED ON DRAWINGS SUPERCEDE MINIMUM SIZES INDICATED IN THIS SCHEDULE.

TRAP SEAL DEVICE.

PROVIDE TERMINATION STYLE AND SIZE FOR FIXTURE CONNECTIONS AS INDICATED BY FIXTURE MANUFACTURER.

-

-

BARRIER

FREE

NO

YES

NO

YES


NO

YES

YES

YES

-

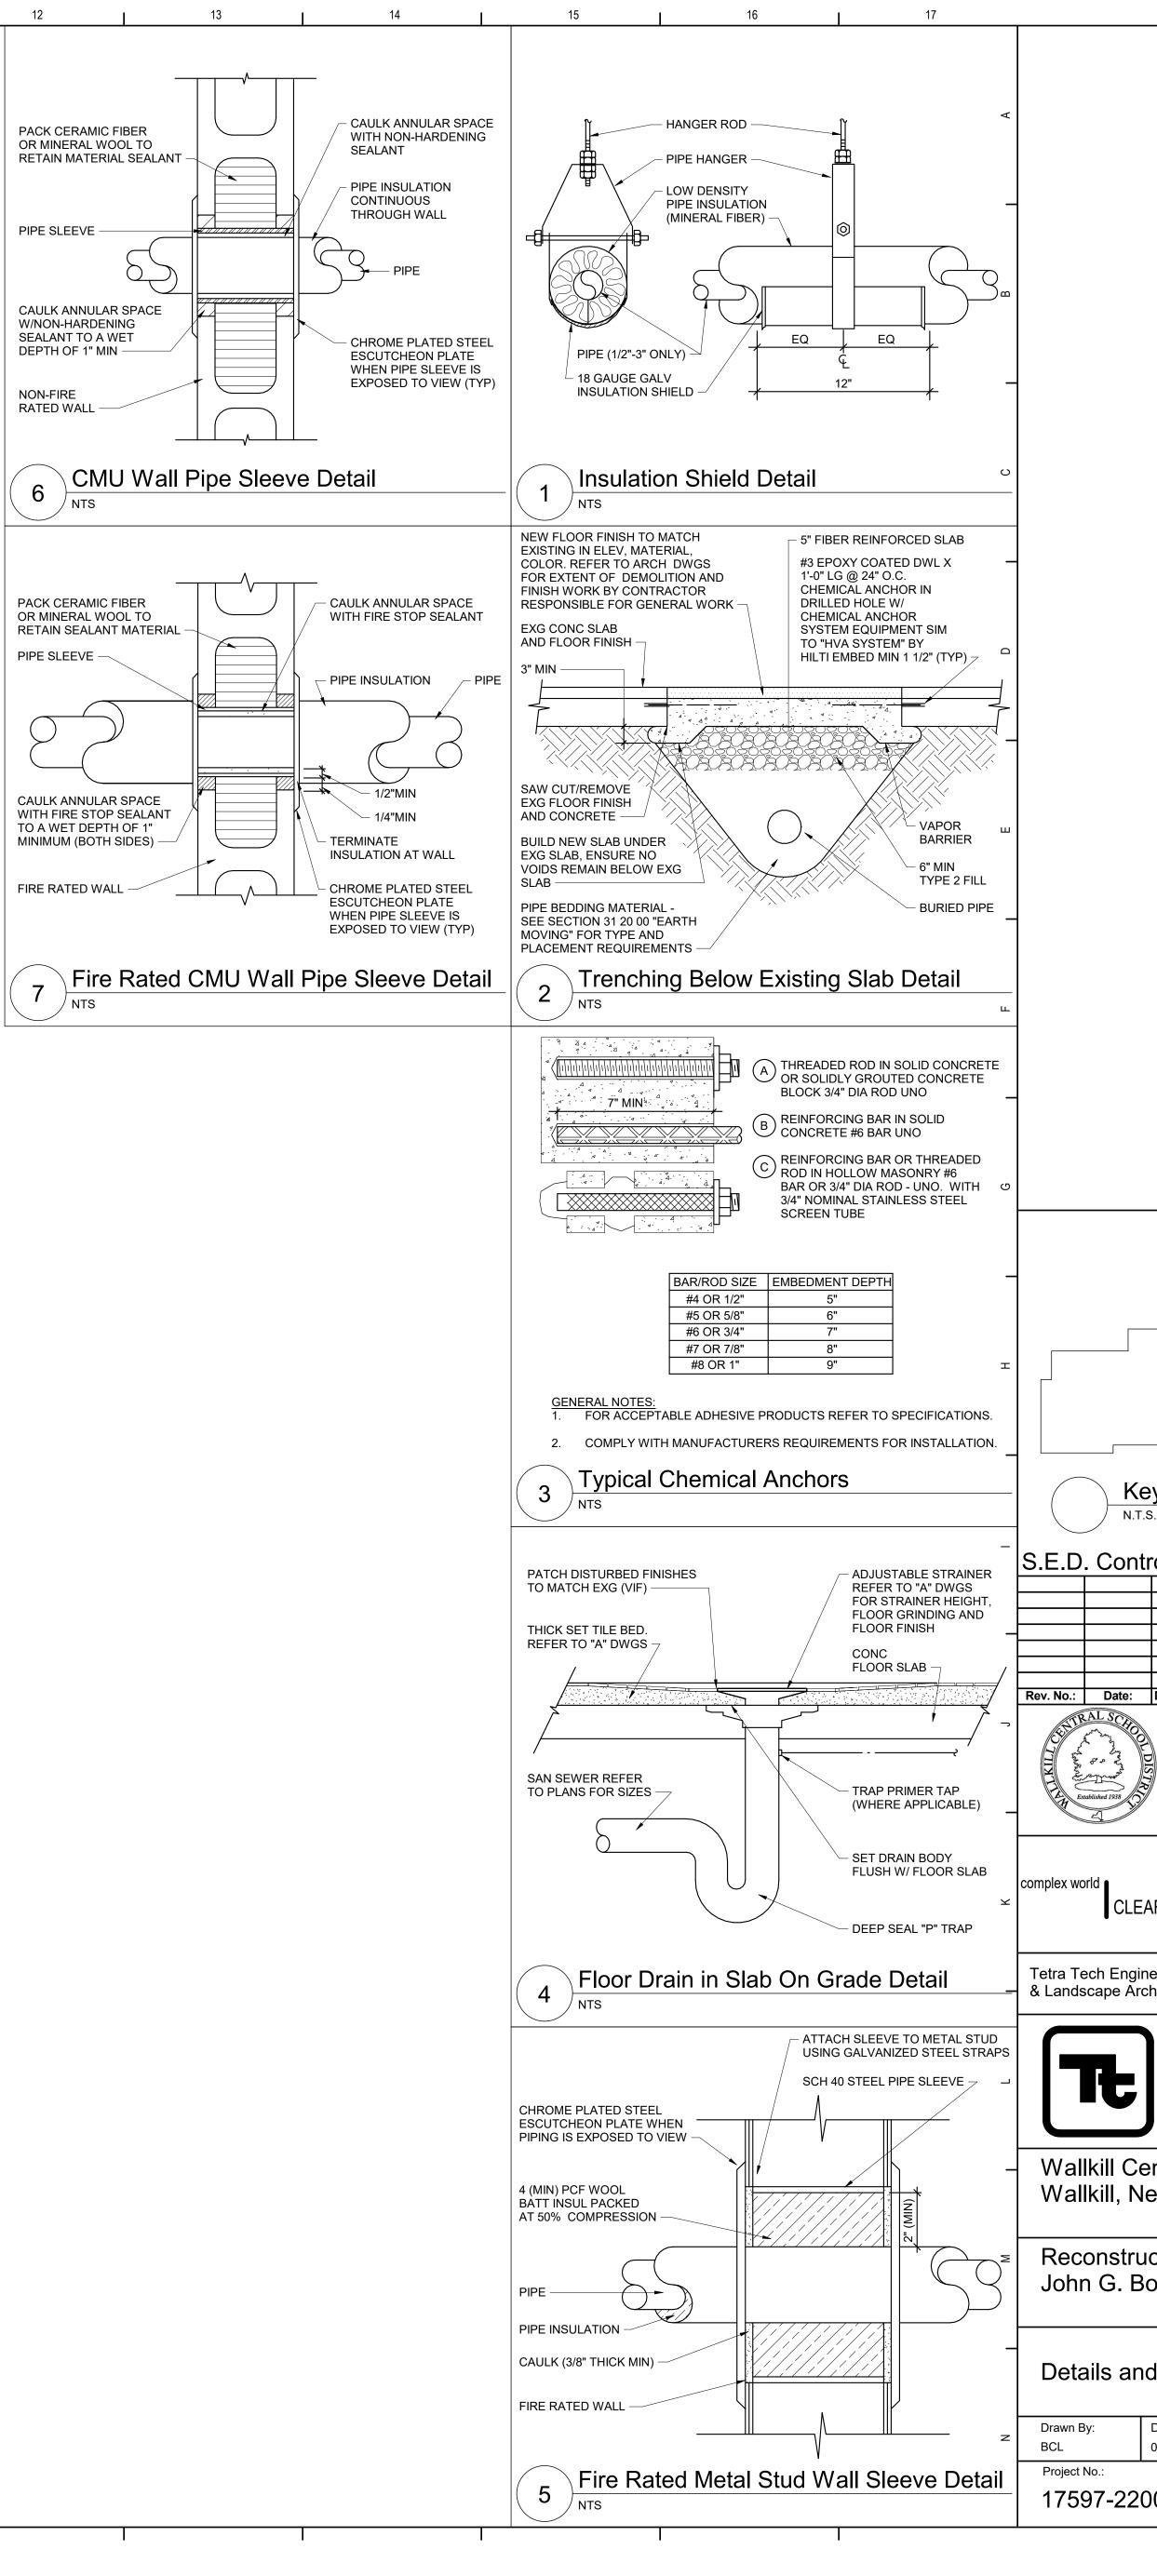

ey Plan ^{s.} rol No. 62-1	8-01-06-0-002-015				
Description:					
CENTRAL	LLKILL SCHOOL DISTRICT				
AR SOLUTIONS eers, Architects hitects, P.C.	BIDSE				
TETRATECH ARCHITECTS & ENGINEERS					
entral School District ew York ction to:					
orden Middle School d Schedule					
Date: 06/30/2023)02	Drawing Number:				