

**NOTES:**

1. REFER TO CONTRACT DRAWING [E-001](#) FOR ELECTRICAL LEGEND, ABBREVIATIONS, GENERAL NOTES, AND DRAWING LIST.
2. REFER TO CONTRACT DRAWINGS [E-701](#), [E-702](#) AND [E-703](#) FOR ELECTRICAL ONE-LINE DIAGRAMS.
3. REFER TO ARCHITECTURAL DRAWINGS FOR EXACT QUANTITY, LOCATION, AND SPECIFICATIONS OF LIGHTING FIXTURES.
4. REFER TO ARCHITECTURAL DRAWINGS FOR EXACT LIGHTING CONTROL SYSTEM SPECIFICATIONS, DEVICE LAYOUT, AND QUANTITY OF CONTROL DEVICES.
5. REFER TO CONTRACT DRAWING [E-807](#) FOR LIGHTING FIXTURE SCHEDULE

ARCHITECT  
**di Domenico + Partners LLP**  
 Architecture  
 Landscape Architecture  
 Planning  
 3743 Crescent Street, 3rd Floor  
 Long Island City, New York 11101  
 Tel 212-337-0400  
 Fax 212-337-3567

CIVIL PLANNING ENGINEER  
**JMC**  
 JMC Planning Engineering Landscape  
 Architecture & Land Surveying, PLLC  
 120 Bedford Road  
 Armonk, New York 10504  
 Tel 914-273-5225  
 Fax 914-273-2102

MEP ENGINEER  
**Burns**  
 BURNS ENGINEERING, PC.  
 1261 Broadway, Suite 708  
 New York, New York 10001  
 Tel 212-962-3503

STRUCTURAL ENGINEER  
**GEI**  
 GEI50  
 1385 Broadway, 20th FL  
 New York, New York 10018  
 Tel 212-687-8282  
 Consultants



**MANHATTAN BEER DISTRIBUTORS**  
 20 DUNNIGAN DRIVE  
 SUFFERN, NEW YORK


KEY PLAN

REV	DESCRIPTION	DATE
	ISSUED FOR DOB SUBMISSION	09/10/2021
	ISSUED FOR BID	10/15/2021
	ISSUED FOR PROGRESS	01/18/2022
	ISSUED FOR BID	08/30/2022

DRAWN BY :  
 CHECKED BY :  
 APPROVED BY :  
 DATE :  
 SCALE :

DRAWING TITLE :  
**ELECTRICAL LIGHTING PLAN - ADMIN ROOF**

DWG NUMBER :  
**E-107**

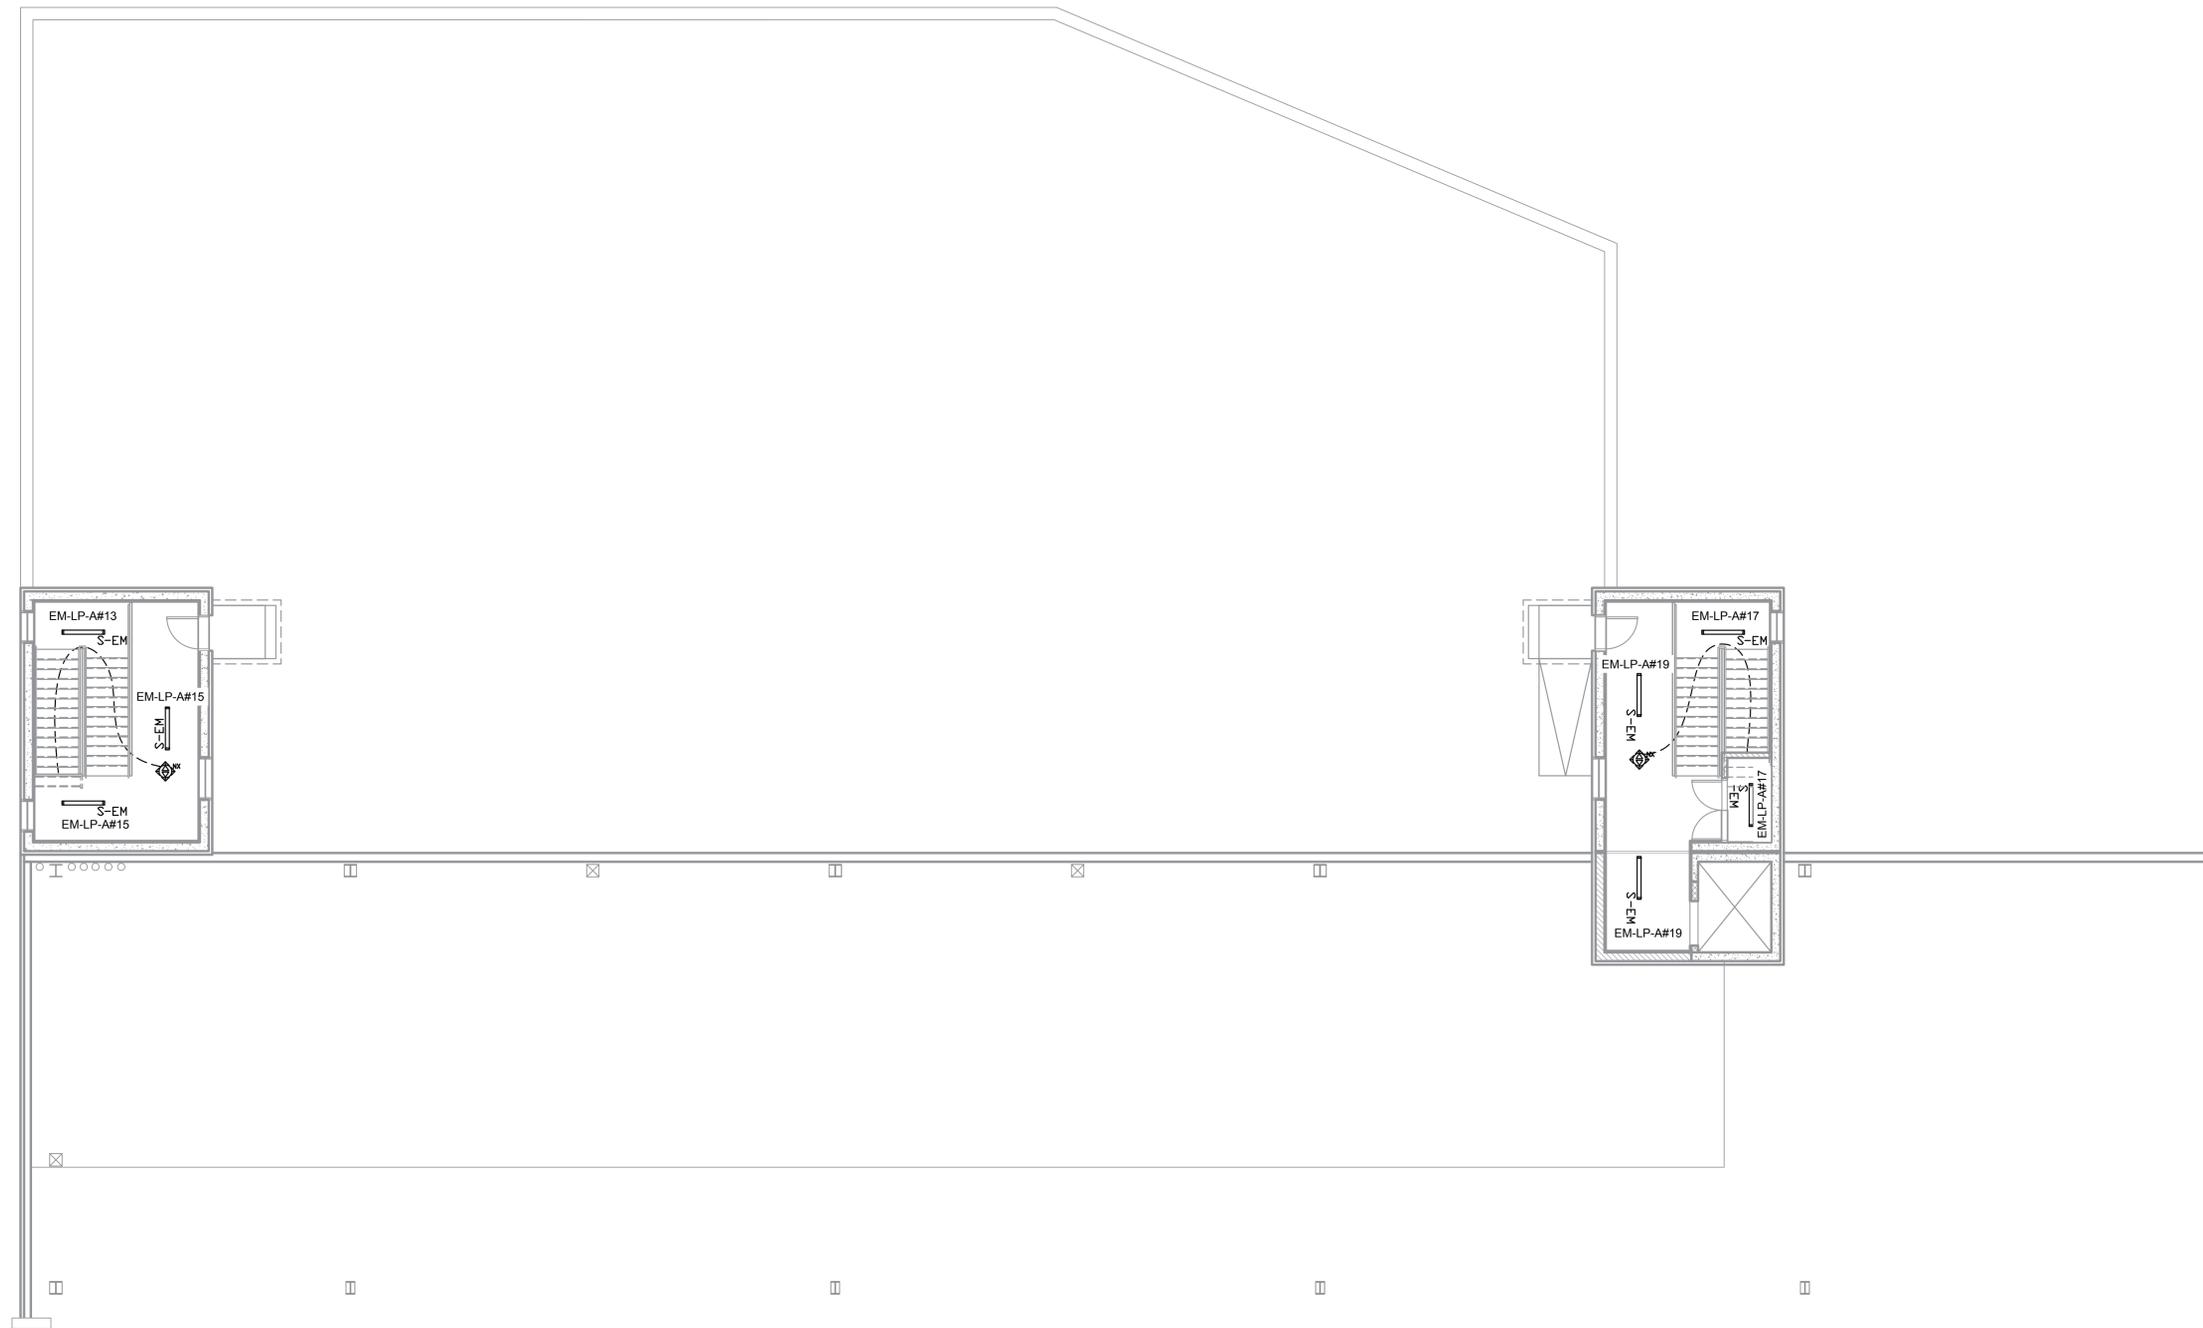

**1**  
**E-107**  
**ELECTRICAL LIGHTING PLAN - ADMIN ROOF**  
 SCALE: 1/8" = 1'-0"  
 0 8 16  
 SCALE IN FEET



TO THE BEST KNOWLEDGE, BELIEF AND PROFESSIONAL JUDGEMENT, THESE PLANS AND SPECIFICATIONS ARE IN COMPLIANCE WITH THE 2020 ENERGY CONSERVATION CONSTRUCTION CODE OF NEW YORK STATE.