

**NOTES:**

1. REFER TO CONTRACT DRAWING E-001 FOR ELECTRICAL LEGEND, ABBREVIATIONS, GENERAL NOTES, AND DRAWING LIST.
2. REFER TO CONTRACT DRAWINGS E-701, E-702, AND E-703 FOR ELECTRICAL ONE-LINE DIAGRAMS.
3. REFER TO CONTRACT DRAWING E-607 FOR LIGHTING FIXTURE SCHEDULE.
4. REFER TO ARCHITECTURAL DRAWINGS FOR EXACT QUANTITY, LOCATION, AND SPECIFICATIONS OF LIGHTING FIXTURES.
5. REFER TO ARCHITECTURAL DRAWINGS FOR EXACT LIGHTING CONTROL SYSTEM SPECIFICATIONS, DEVICE LAYOUT, AND QUANTITY OF CONTROL DEVICES.

ARCHITECT  
**di Domenico + Partners LLP**  
 Architecture  
 Landscape Architecture  
 Planning  
 3743 Crescent Street, 3rd Floor  
 Long Island City, New York 11101  
 Tel 212-337-0400  
 Fax 212-337-3567

 
CIVIL PLANNING ENGINEER  
**JMC**  
 JMC Planning Engineering Landscape  
 Architecture & Land Surveying, PLLC  
 120 Bedford Road  
 Armonk, New York 10504  
 Tel 914-273-5225  
 Fax 914-273-2102

MEP ENGINEER  
**Burns**  
 BURNS ENGINEERING, PC.  
 1261 Broadway, Suite 708  
 New York, New York 10001  
 Tel 212-962-3503

STRUCTURAL ENGINEER  
**GEI**  
 GEI50  
 1385 Broadway, 20th FL  
 New York, New York 10018  
 Tel 212-687-8282



**MANHATTAN BEER DISTRIBUTORS**  
 20 DUNNIGAN DRIVE  
 SUFFERN, NEW YORK




REV	DESCRIPTION	DATE
	ISSUED FOR DOB SUBMISSION	09/10/2021
	ISSUED FOR BID	10/15/2021
	ISSUED FOR PROGRESS	01/18/2022
	ISSUED FOR BID	08/30/2022

DRAWN BY :	M.DIMATTIA
CHECKED BY :	B.NEMCHEK
APPROVED BY :	J.MIZRAHI
DATE :	09/10/21
SCALE :	AS NOTED

DRAWING TITLE:  
**ELECTRICAL SITE LIGHTING PLAN - 10 DUNNIGAN (NORTH)**

DWG NUMBER :  
**E-109**

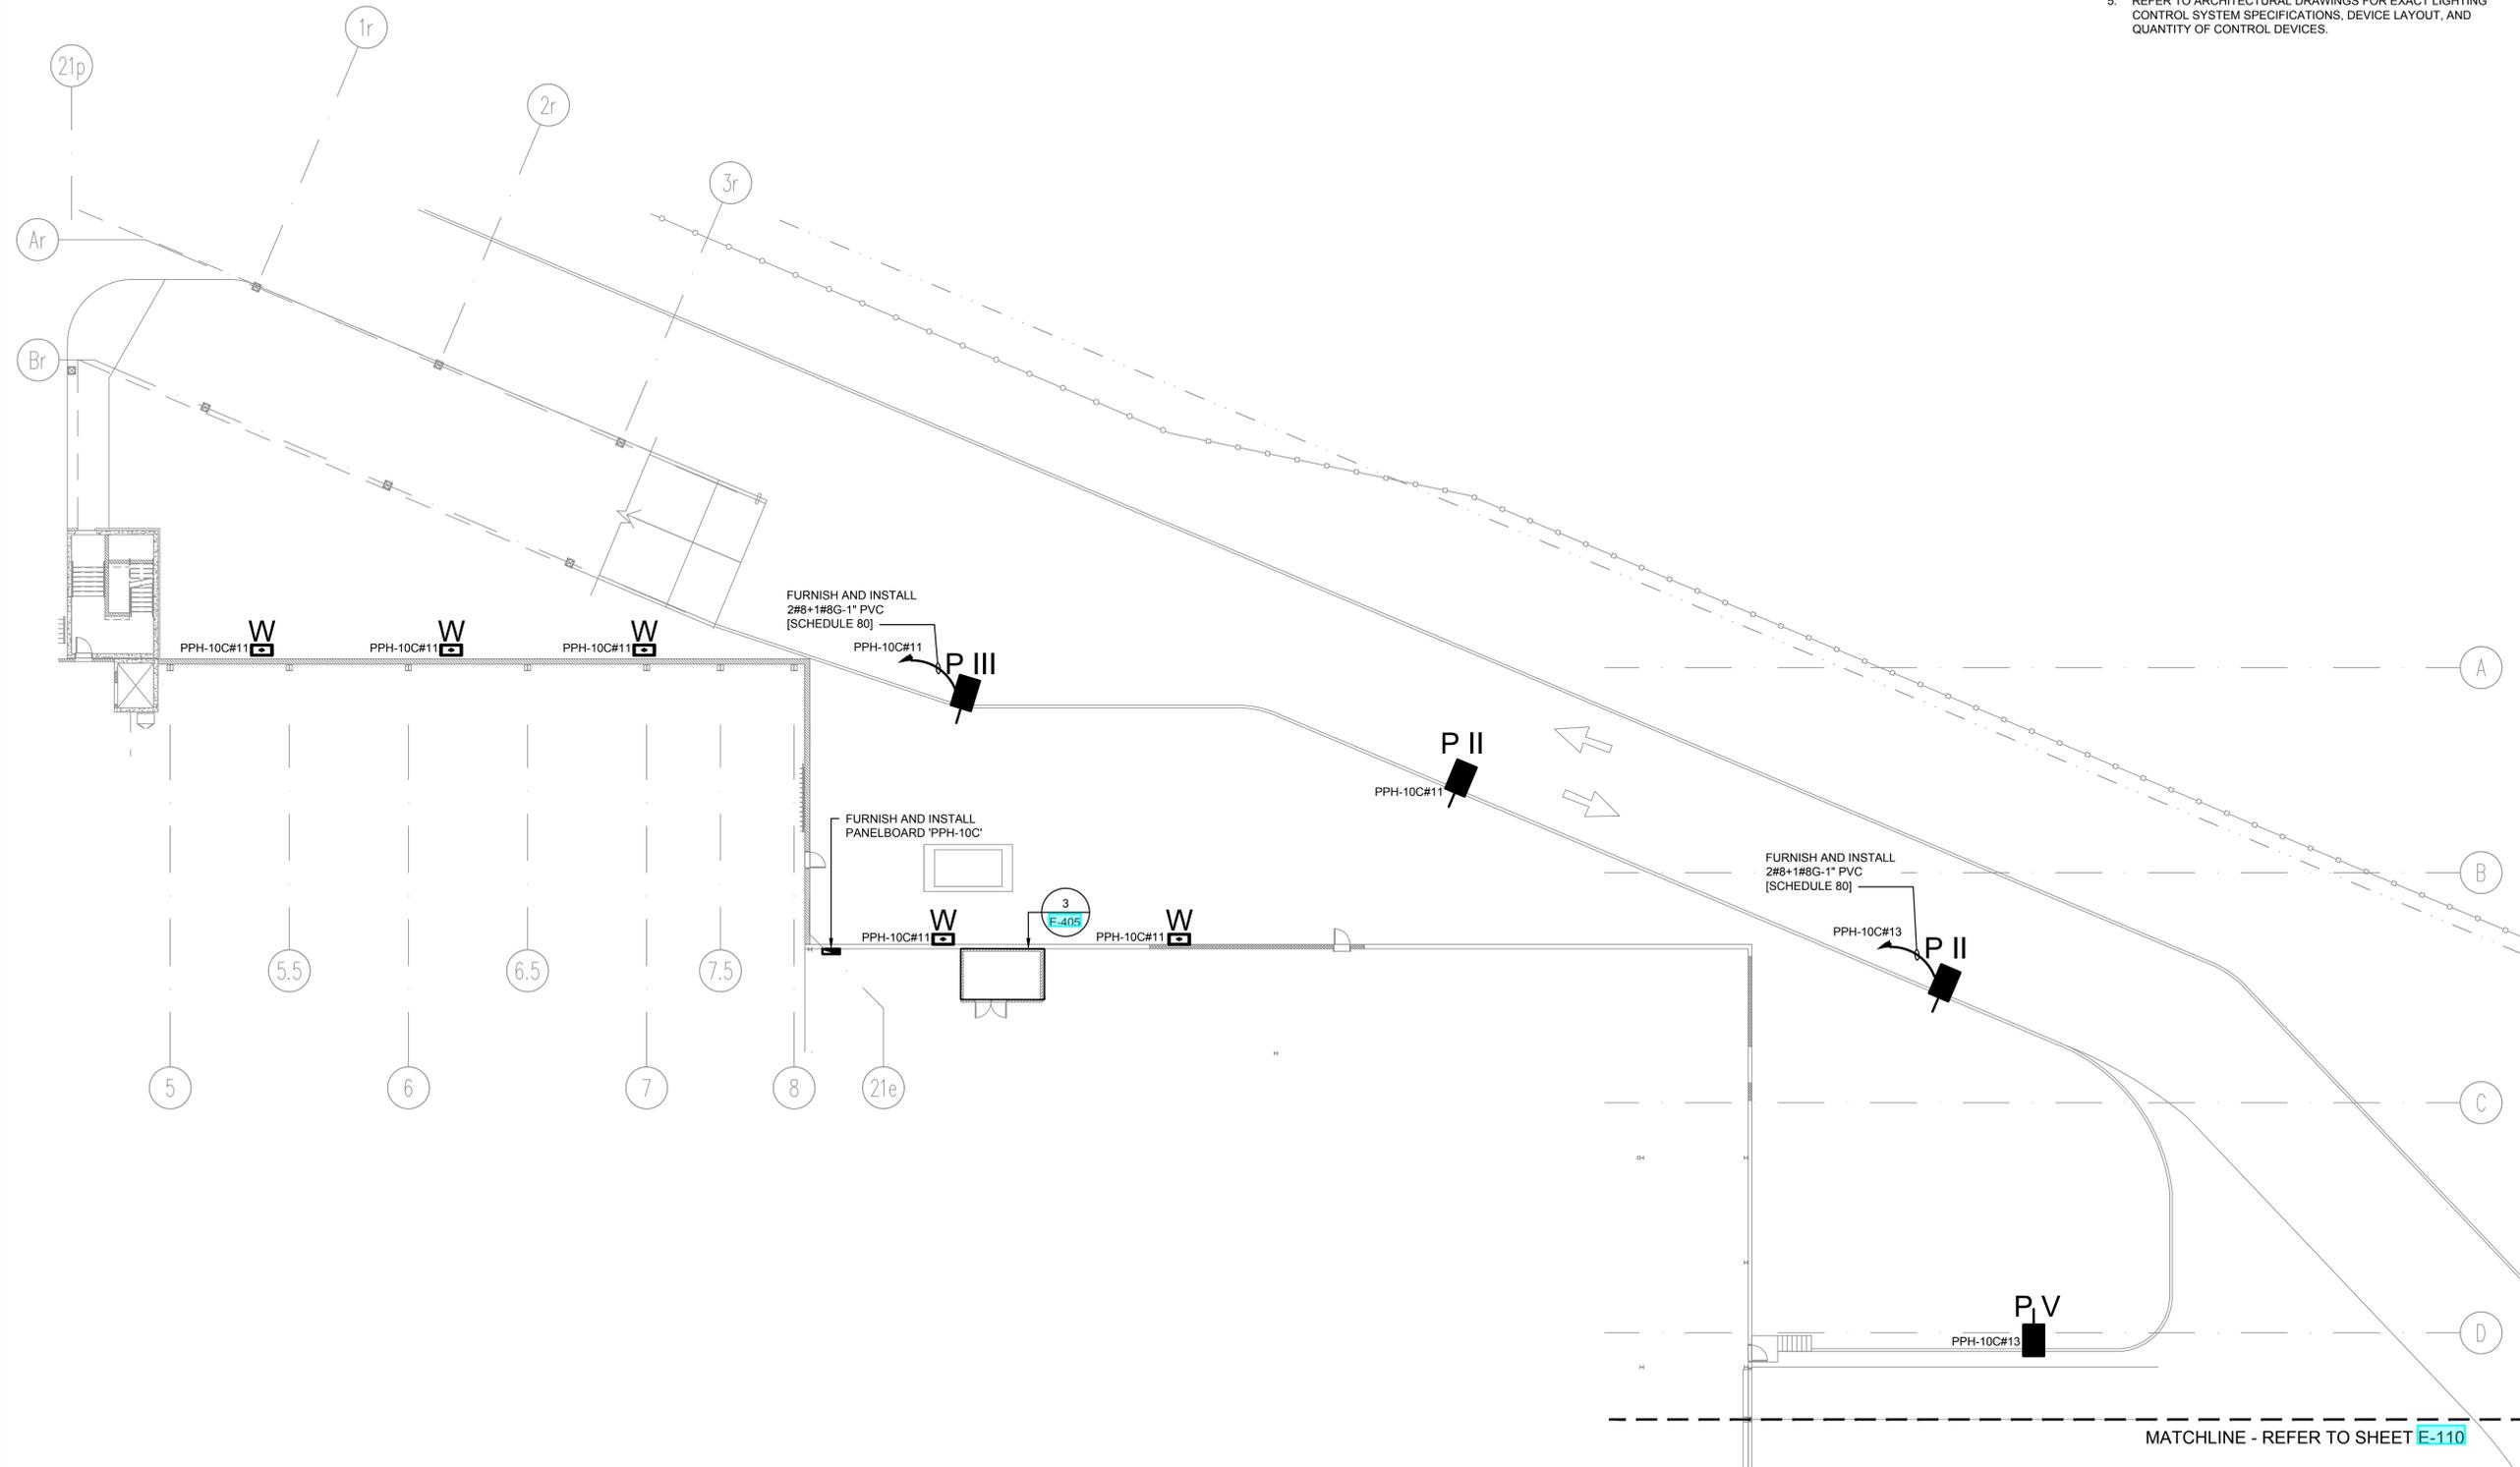

**1**  
**ELECTRICAL SITE LIGHTING PLAN - 10 DUNNIGAN (NORTH)**  
 E-109 SCALE: 1/16" = 1'-0"  
 0 16 32  
 SCALE IN FEET



TO THE BEST KNOWLEDGE, BELIEF AND PROFESSIONAL JUDGEMENT, THESE PLANS AND SPECIFICATIONS ARE IN COMPLIANCE WITH THE 2020 ENERGY CONSERVATION CONSTRUCTION CODE OF NEW YORK STATE.