

AS/RS SYSTEM LEGEND	
SYMBOL	DESCRIPTION
(A)	SRM
(G)	VRC
(B)	MCP
(F)	CONTROL PANEL
(H)	MAINTENANCE RECEPTACLES
(1)	DATA CONNECTION

NOTE: REFER TO AS/RS MANUFACTURER DRAWINGS FOR EXACT POWER REQUIREMENTS AND LOCATIONS OF AS/RS MACHINES AND EQUIPMENT

- NOTES:**
- REFER TO CONTRACT DRAWING E-001 FOR ELECTRICAL LEGEND, ABBREVIATIONS, GENERAL NOTES, AND DRAWING LIST.
  - REFER TO CONTRACT DRAWINGS E-701, E-702, AND E-703 FOR ELECTRICAL ONE-LINE DIAGRAMS.
  - REFER TO ARCHITECTURAL DRAWINGS FOR EXACT QUANTITY AND LOCATIONS OF RECEPTACLES AND DATA OUTLETS.
  - REFER TO AS/RS MANUFACTURER DRAWINGS FOR EXACT REQUIREMENTS OF AS/RS EQUIPMENT.

 
ARCHITECT  
**di Domenico + Partners LLP**  
 Architecture  
 Landscape Architecture  
 Planning  
 3743 Crescent Street, 3rd Floor  
 Long Island City, New York 11101  
 Tel 212-337-0400  
 Fax 212-337-3567

CIVIL PLANNING ENGINEER  
**JMC**  
 JMC Planning Engineering Landscape  
 Architecture & Land Surveying, PLLC  
 120 Bedford Road  
 Armonk, New York 10504  
 Tel 914-273-5225  
 Fax 914-273-2102

MEP ENGINEER  
**Burns** BURNS ENGINEERING, PC.  
 1261 Broadway, Suite 708  
 New York, New York 10001  
 Tel 212-962-3503

STRUCTURAL ENGINEER  
**GEI** GEI50  
 1385 Broadway, 20th FL  
 New York, New York 10018  
 Tel 212-687-8282

**MANHATTAN BEER DISTRIBUTORS**  
 MANHATTAN BEER DISTRIBUTORS  
 20 DUNNIGAN DRIVE  
 SUFFERN, NEW YORK




REV	DESCRIPTION	DATE
	ISSUED FOR DOB SUBMISSION	09/10/2021
	ISSUED FOR BID	10/15/2021
	ISSUED FOR PROGRESS	01/18/2022
	ISSUED FOR BID	08/30/2022

DRAWN BY: M.DIMATTIA  
 CHECKED BY: B.NEMCHEK  
 APPROVED BY: J.MIZRAHI  
 DATE: 09/10/21  
 SCALE: AS NOTED

DRAWING TITLE:  
**ELECTRICAL POWER PLAN - WAREHOUSE LEVEL (NORTH)**

DWG NUMBER:  
**E-201**

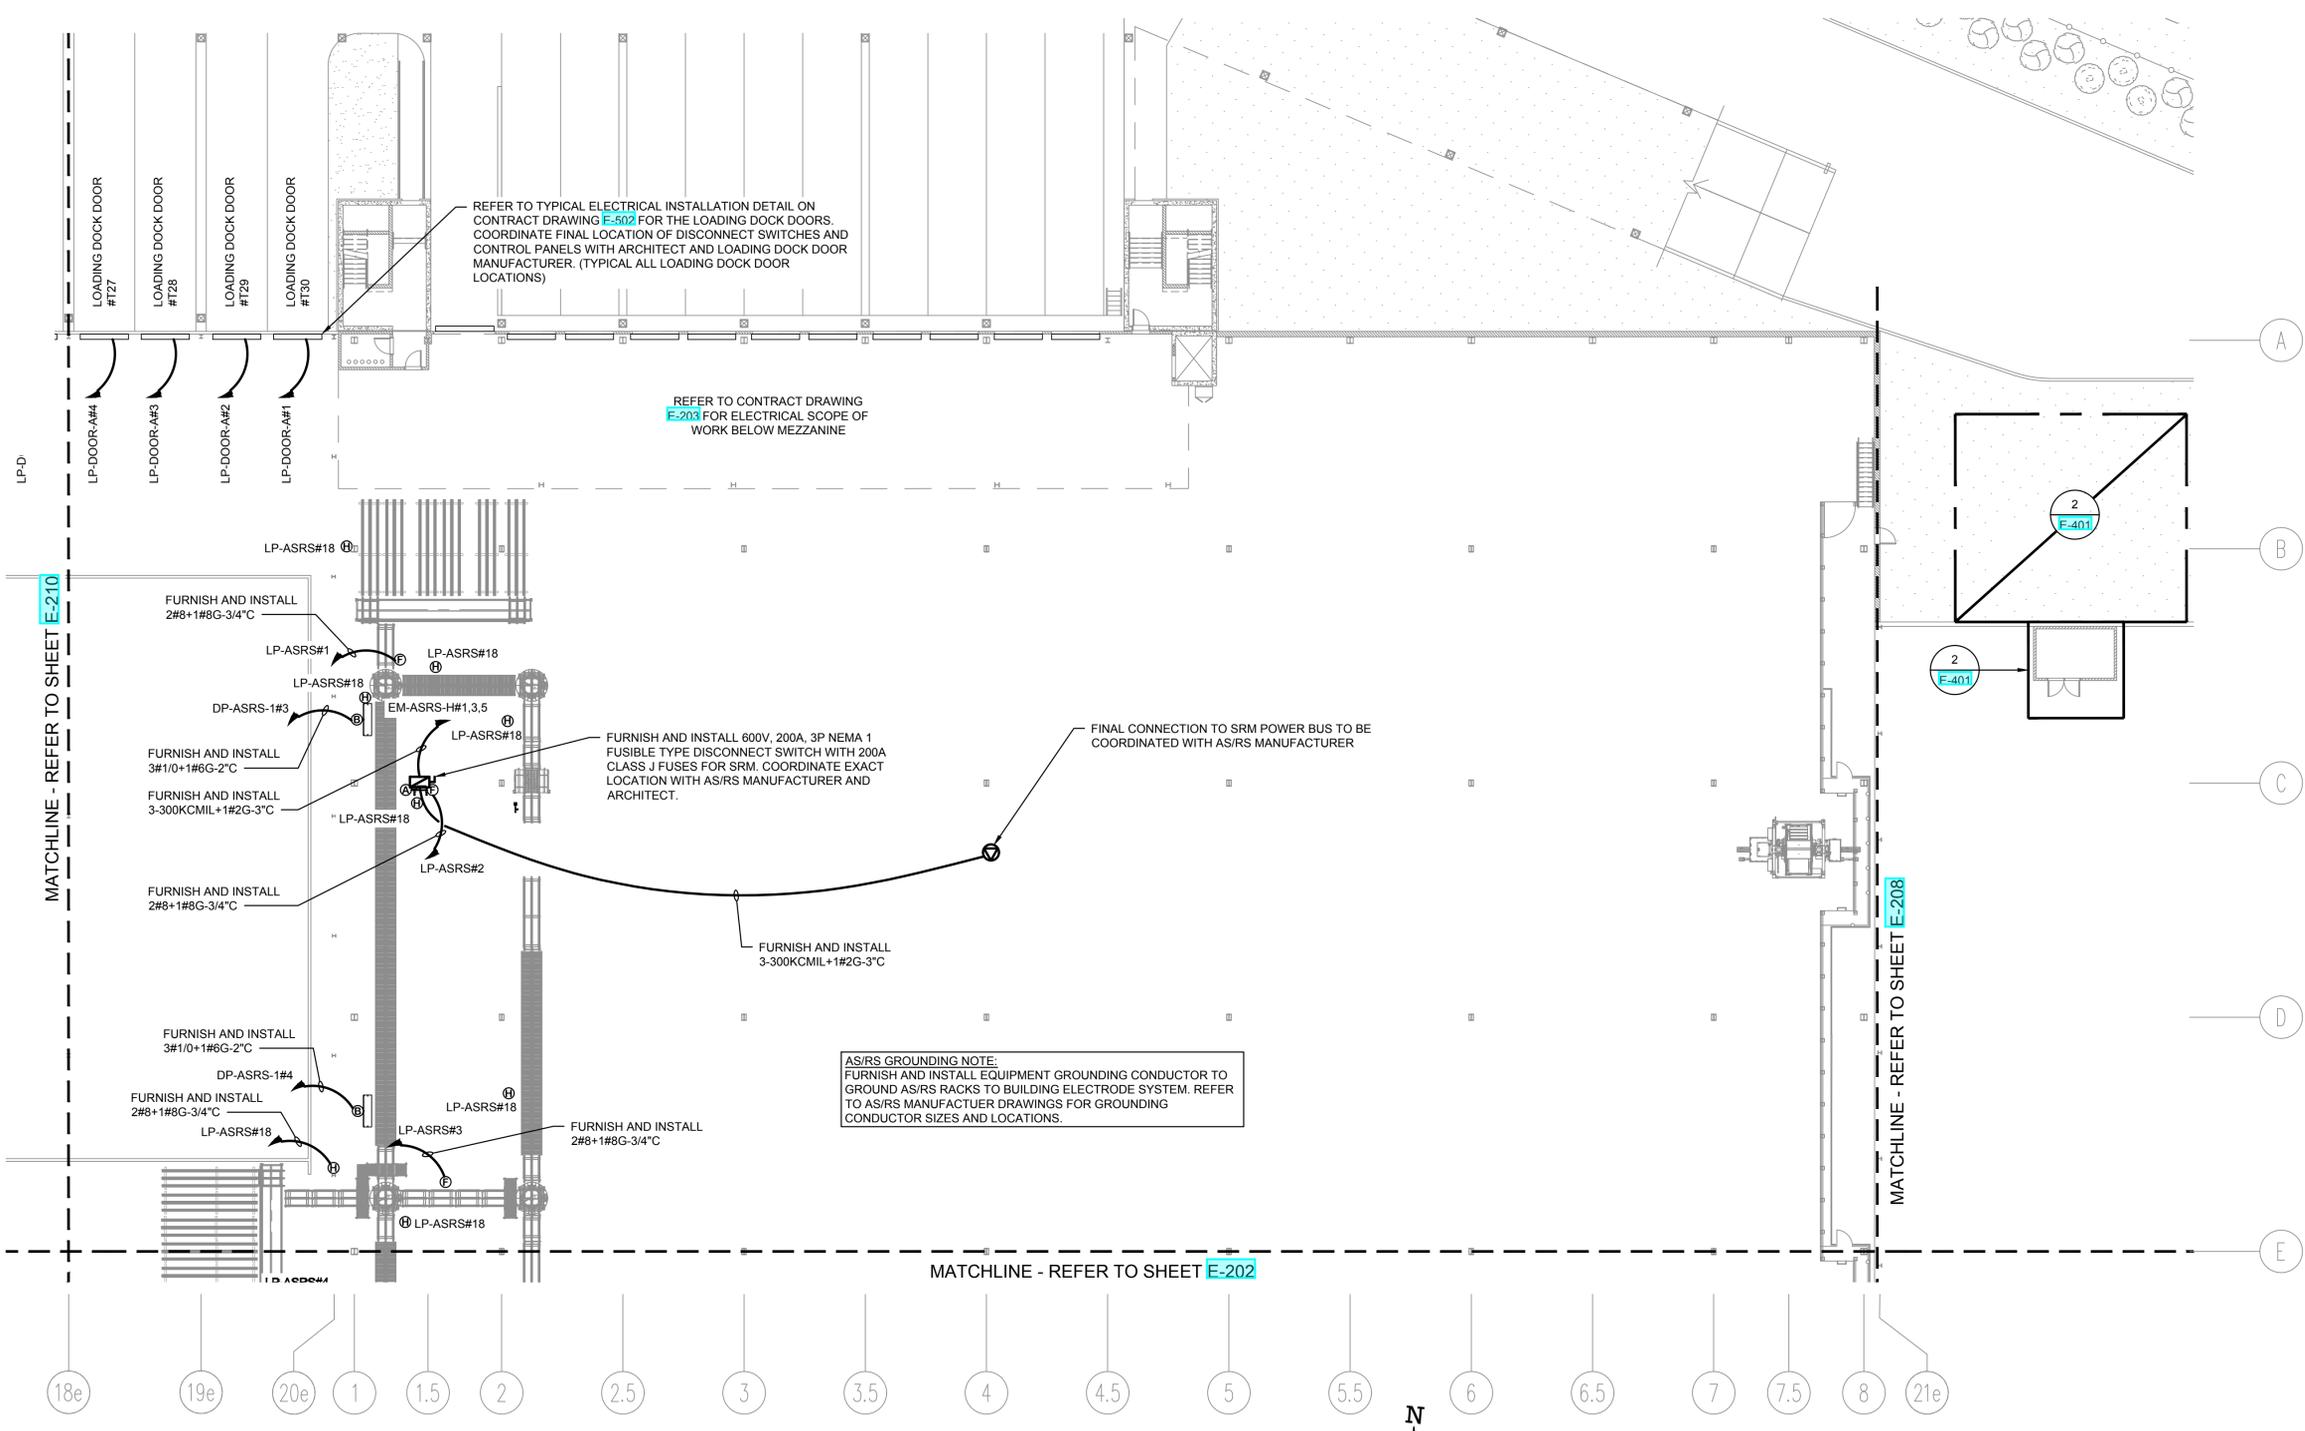

**1**  
 E-201  
**ELECTRICAL POWER PLAN - WAREHOUSE LEVEL (NORTH)**  
 SCALE: 1/16" = 1'-0"  
 0 16 32  
 SCALE IN FEET

TO THE BEST KNOWLEDGE, BELIEF AND PROFESSIONAL JUDGEMENT, THESE PLANS AND SPECIFICATIONS ARE IN COMPLIANCE WITH THE 2020 ENERGY CONSERVATION CONSTRUCTION CODE OF NEW YORK STATE.