

NOTES:

1. REFER TO CONTRACT DRAWING E-001 FOR ELECTRICAL LEGEND, ABBREVIATIONS, GENERAL NOTES, AND DRAWING LIST.
2. REFER TO CONTRACT DRAWINGS E-701, E-702, AND E-703 FOR ELECTRICAL ONE-LINE DIAGRAMS AND ELECTRICAL REQUIREMENTS OF EQUIPMENT.
3. REFER TO ARCHITECTURAL DRAWINGS FOR EXACT QUANTITY AND LOCATIONS OF RECEPTACLES AND DATA OUTLETS.
4. ALL RECEPTACLES AND EQUIPMENT SHOWN ON THIS DRAWING SHALL BE FED FROM PANEL 'PP-A' UNLESS OTHERWISE NOTED.

ARCHITECT
di Domenico + Partners LLP
 Architecture
 Landscape Architecture
 Planning
 3743 Crescent Street, 3rd Floor
 Long Island City, New York 11101
 Tel 212-337-0400
 Fax 212-337-3567

 
CIVIL PLANNING ENGINEER
JMC
 JMC Planning Engineering Landscape
 Architecture & Land Surveying, PLLC
 120 Bedford Road
 Armonk, New York 10504
 Tel 914-273-5225
 Fax 914-273-2102

MEP ENGINEER
Burns BURNS ENGINEERING, PC.
 1261 Broadway, Suite 708
 New York, New York 10001
 Tel 212-962-3503

STRUCTURAL ENGINEER
GEI GEI50
 1385 Broadway, 20th FL
 New York, New York 10018
 Tel 212-687-8282



MANHATTAN BEER DISTRIBUTORS
 20 DUNNIGAN DRIVE
 SUFFERN, NEW YORK




REV	DESCRIPTION	DATE
	ISSUED FOR DOB SUBMISSION	09/10/2021
	ISSUED FOR BID	10/15/2021
	ISSUED FOR PROGRESS	01/18/2022
	ISSUED FOR BID	08/30/2022

DRAWN BY :	M.DIMATTIA
CHECKED BY :	B.NEMCHEK
APPROVED BY :	J.MIZRAHI
DATE :	09/10/21
SCALE :	AS NOTED

DRAWING TITLE :
ELECTRICAL POWER PLAN - ADMIN OFFICE

DWG NUMBER :	E-205
--------------	-------

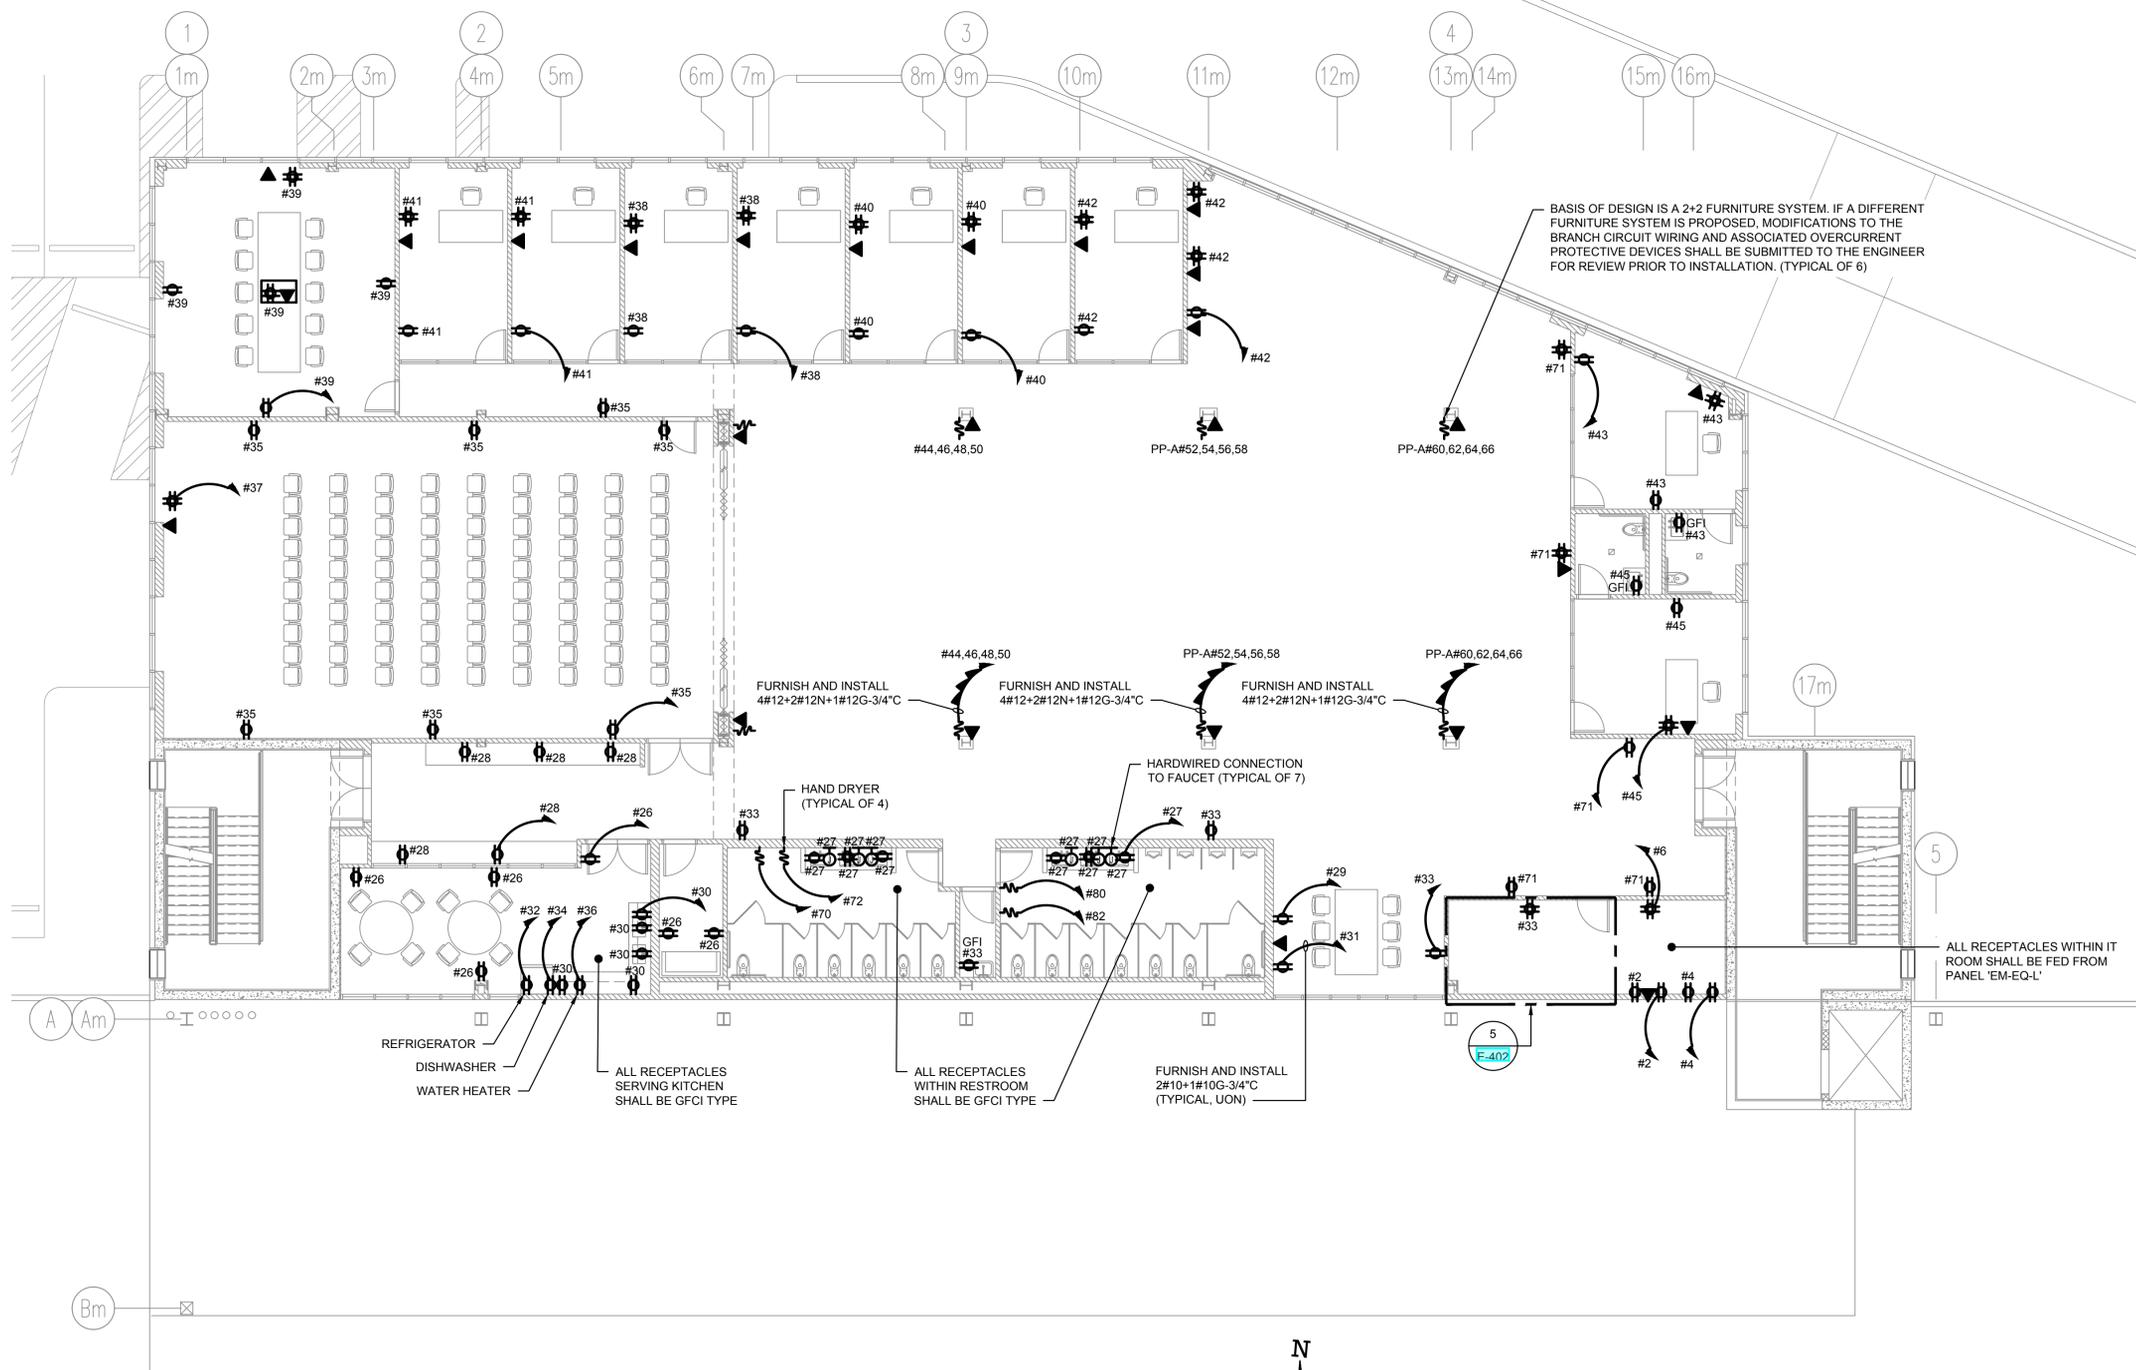

BASIS OF DESIGN IS A 2+2 FURNITURE SYSTEM. IF A DIFFERENT FURNITURE SYSTEM IS PROPOSED, MODIFICATIONS TO THE BRANCH CIRCUIT WIRING AND ASSOCIATED OVERCURRENT PROTECTIVE DEVICES SHALL BE SUBMITTED TO THE ENGINEER FOR REVIEW PRIOR TO INSTALLATION. (TYPICAL OF 6)

1
 E-205
ELECTRICAL POWER PLAN - ADMIN OFFICE
 SCALE: 1/8" = 1'-0"
 0 8 16
 SCALE IN FEET



TO THE BEST KNOWLEDGE, BELIEF AND PROFESSIONAL JUDGEMENT, THESE PLANS AND SPECIFICATIONS ARE IN COMPLIANCE WITH THE 2020 ENERGY CONSERVATION CONSTRUCTION CODE OF NEW YORK STATE.