

NOTES:


1. REFER TO CONTRACT DRAWING E-001 FOR ELECTRICAL LEGEND, ABBREVIATIONS, GENERAL NOTES, AND DRAWING LIST.
2. REFER TO CONTRACT DRAWINGS E-701, E-702, AND E-703 FOR ELECTRICAL ONE-LINE DIAGRAMS.
3. REFER TO ARCHITECTURAL DRAWINGS FOR EXACT QUANTITY AND LOCATIONS OF RECEPTACLES AND DATA OUTLETS.

ARCHITECT
di Domenico + Partners LLP
 Architecture
 Landscape Architecture
 Planning
 3743 Crescent Street, 3rd Floor
 Long Island City, New York 11101
 Tel 212-337-0400
 Fax 212-337-3567



CIVIL PLANNING ENGINEER
JMC
 JMC Planning Engineering Landscape
 Architecture & Land Surveying, PLLC
 120 Bedford Road
 Armonk, New York 10504
 Tel 914-273-5225
 Fax 914-273-2102

MEP ENGINEER
Burns
 BURNS ENGINEERING, PC.
 1261 Broadway, Suite 708
 New York, New York 10001
 Tel 212-962-3503

STRUCTURAL ENGINEER
GEI
 GEI50
 1385 Broadway, 20th FL
 New York, New York 10018
 Tel 212-687-8282

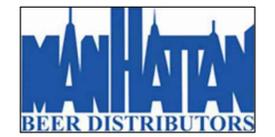

 MANHATTAN BEER DISTRIBUTORS
 20 DUNNIGAN DRIVE
 SUFFERN, NEW YORK

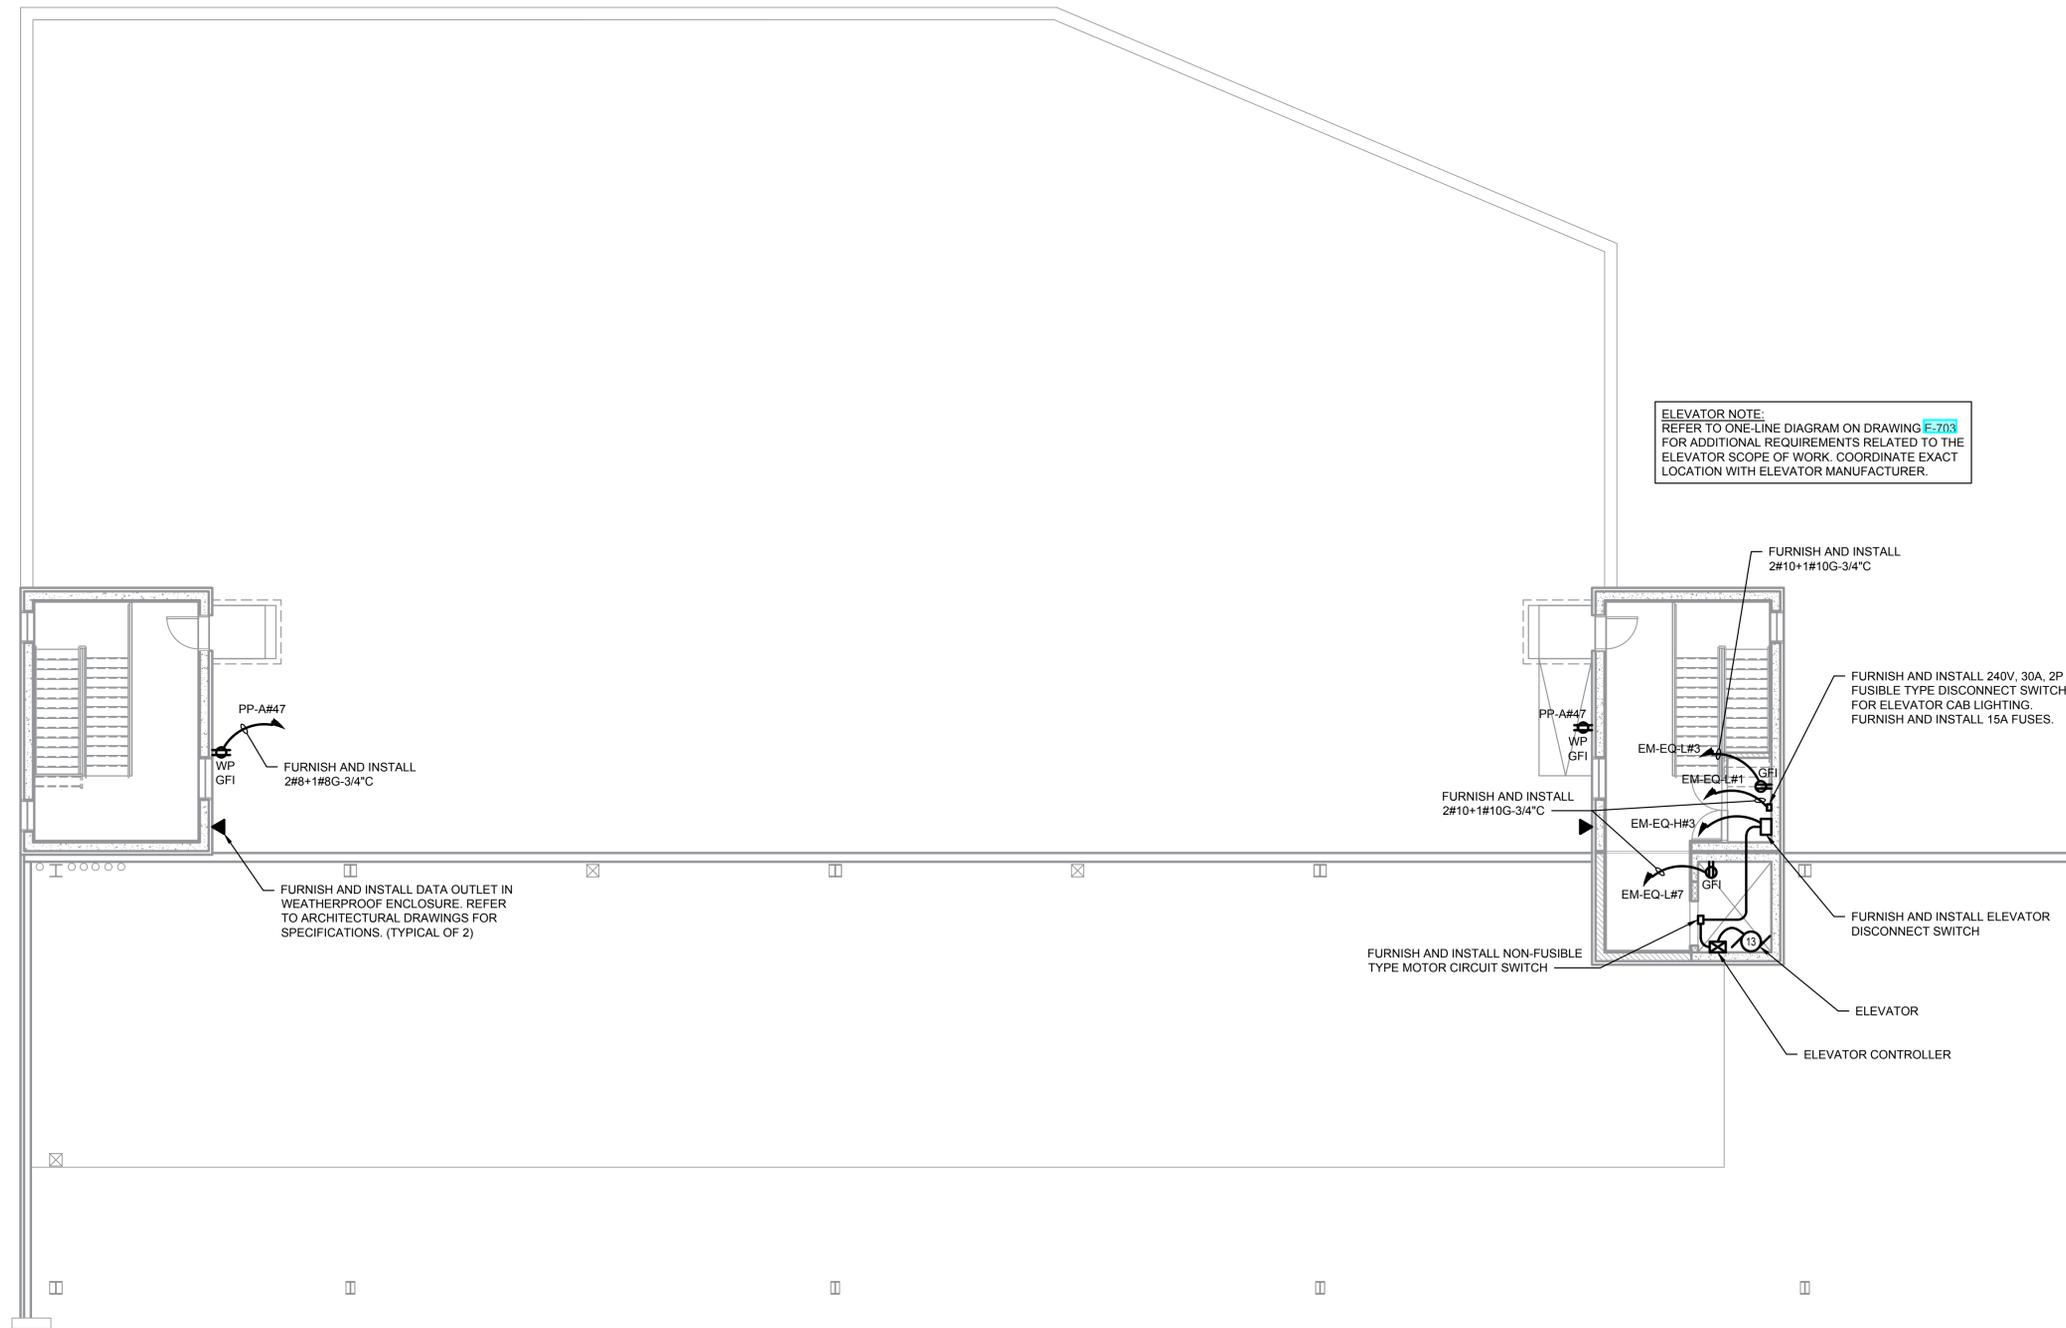

ELEVATOR NOTE:
 REFER TO ONE-LINE DIAGRAM ON DRAWING E-703 FOR ADDITIONAL REQUIREMENTS RELATED TO THE ELEVATOR SCOPE OF WORK. COORDINATE EXACT LOCATION WITH ELEVATOR MANUFACTURER.

REV	DESCRIPTION	DATE
	ISSUED FOR DOB SUBMISSION	09/10/2021
	ISSUED FOR BID	10/15/2021
	ISSUED FOR PROGRESS	01/18/2022
	ISSUED FOR BID	08/30/2022

DRAWN BY : M.DIMATTIA
 CHECKED BY : B.NEMCHEK
 APPROVED BY : J.MIZRAHI
 DATE : 09/10/21
 SCALE : AS NOTED

DRAWING TITLE :
ELECTRICAL POWER PLAN - ADMIN ROOF

DWG NUMBER :
E-207

1
 E-207
ELECTRICAL POWER PLAN - ADMIN ROOF
 SCALE: 1/8" = 1'-0"
 0 16 32
 SCALE IN FEET



TO THE BEST KNOWLEDGE, BELIEF AND PROFESSIONAL JUDGEMENT, THESE PLANS AND SPECIFICATIONS ARE IN COMPLIANCE WITH THE 2020 ENERGY CONSERVATION CONSTRUCTION CODE OF NEW YORK STATE.