

ARCHITECT
di Domenico + Partners LLP
 Architecture
 Landscape Architecture
 Planning
 3743 Crescent Street, 3rd Floor
 Long Island City, New York 11101
 Tel 212-337-0400
 Fax 212-337-3567

 
CIVIL PLANNING ENGINEER
JMC
 JMC Planning Engineering Landscape
 Architecture & Land Surveying, PLLC
 120 Bedford Road
 Armonk, New York 10504
 Tel 914-273-5225
 Fax 914-273-2102

MEP ENGINEER
Burns
 BURNS ENGINEERING, PC.
 1261 Broadway, Suite 708
 New York, New York 10001
 Tel 212-962-3503

STRUCTURAL ENGINEER
GEI
 GEI50
 1385 Broadway, 20th FL
 New York, New York 10001
 Tel 212-687-8282



MANHATTAN BEER DISTRIBUTORS
 20 DUNNIGAN DRIVE
 SUFFERN, NEW YORK



REV	DESCRIPTION	DATE
	ISSUED FOR DOB SUBMISSION	09/10/2021
	ISSUED FOR BID	10/15/2021
	ISSUED FOR PROGRESS	01/18/2022
	ISSUED FOR BID	08/30/2022

DRAWN BY :	M.DIMATTIA
CHECKED BY :	B.NEMCHEK
APPROVED BY :	J.MIZRAHI
DATE :	09/10/21
SCALE :	AS NOTED

DRAWING TITLE:
MECHANICAL POWER PLAN - ADMIN ROOF


DWG NUMBER :
E-307

NOTES:

- REFER TO CONTRACT DRAWING E-001 FOR ELECTRICAL LEGEND, ABBREVIATIONS, GENERAL NOTES, AND DRAWING LIST.
- REFER TO CONTRACT DRAWINGS E-701, E-702, AND E-703 FOR ELECTRICAL ONE-LINE DIAGRAMS.
- REFER TO MECHANICAL CONTRACT DRAWINGS FOR EXACT LOCATION AND REQUIREMENTS OF MECHANICAL EQUIPMENT.

KEY NOTES:

- FURNISH AND INSTALL 600V, 30A, 3P, NEMA 3R, NON-FUSIBLE TYPE DISCONNECT SWITCH.
- FURNISH AND INSTALL 600V, 30A, 2P, NEMA 3R, NON-FUSIBLE TYPE DISCONNECT SWITCH.
- FURNISH AND INSTALL 600V, 60A, 2P, NEMA 3R, NON-FUSIBLE TYPE DISCONNECT SWITCH.

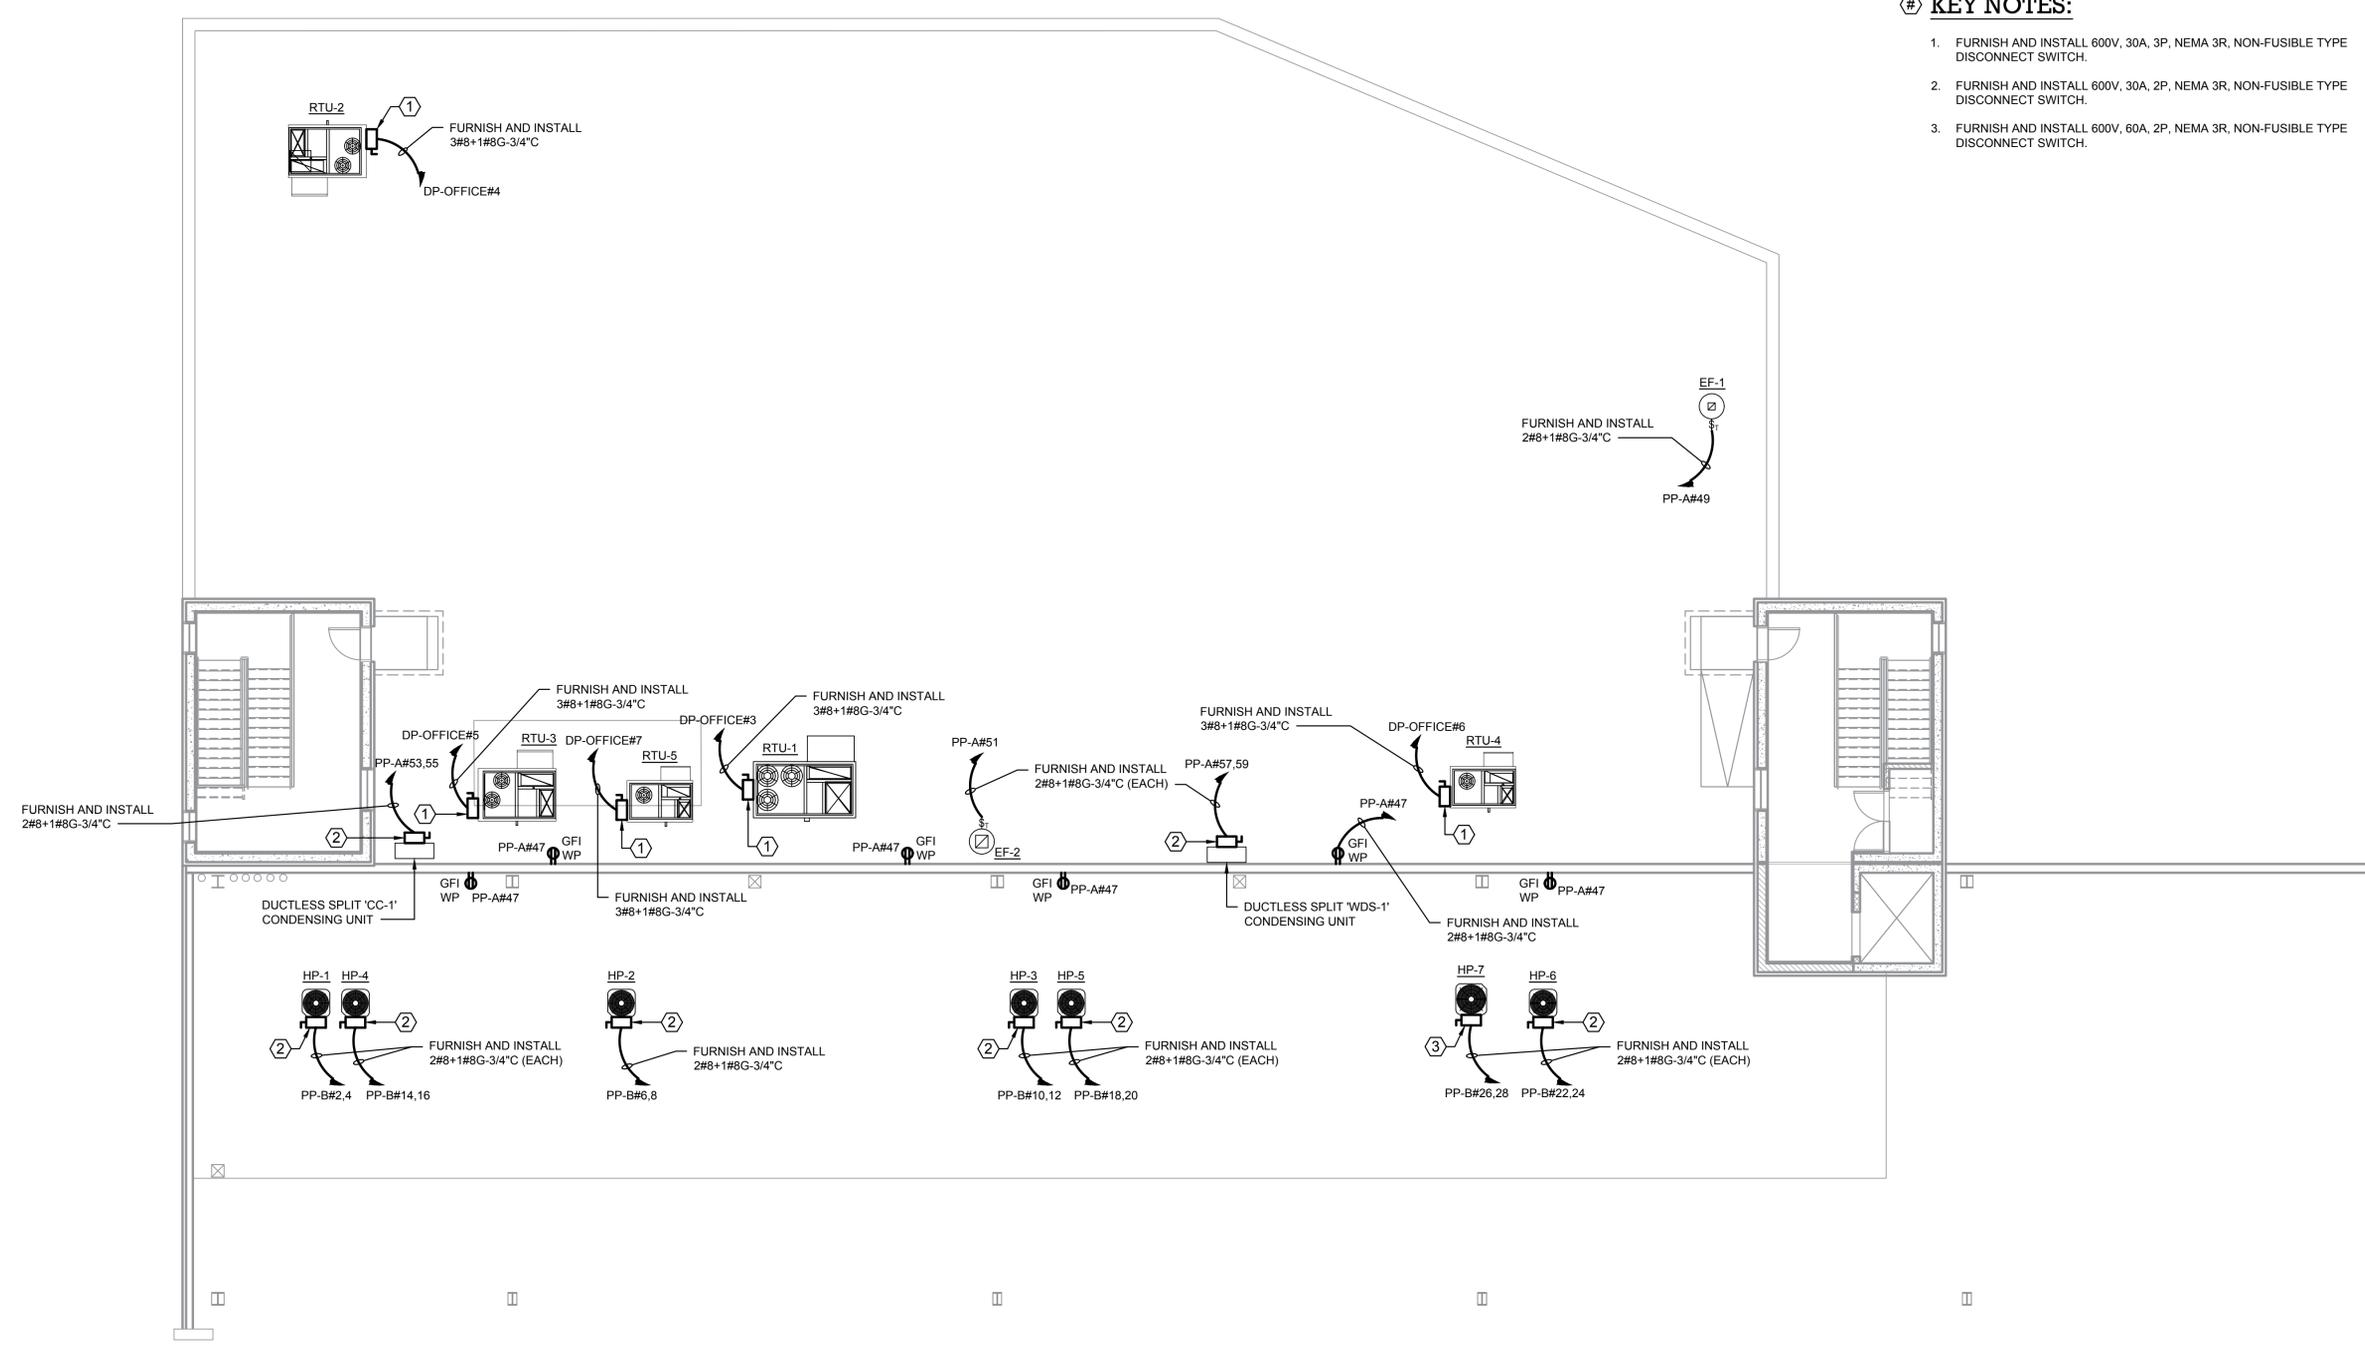

1
 E-307
MECHANICAL POWER PLAN - ADMIN ROOF
 SCALE: 1/8" = 1'-0"
 0 16 32
 SCALE IN FEET



TO THE BEST KNOWLEDGE, BELIEF AND PROFESSIONAL JUDGEMENT, THESE PLANS AND SPECIFICATIONS ARE IN COMPLIANCE WITH THE 2020 ENERGY CONSERVATION CONSTRUCTION CODE OF NEW YORK STATE.