


2 **ELECTRICAL LIGHTING PART PLAN - 20 DUNNIGAN NEW BUILDING ADDITION ELECTRICAL ROOM**
 E-404 SCALE: 3/8" = 1'-0"

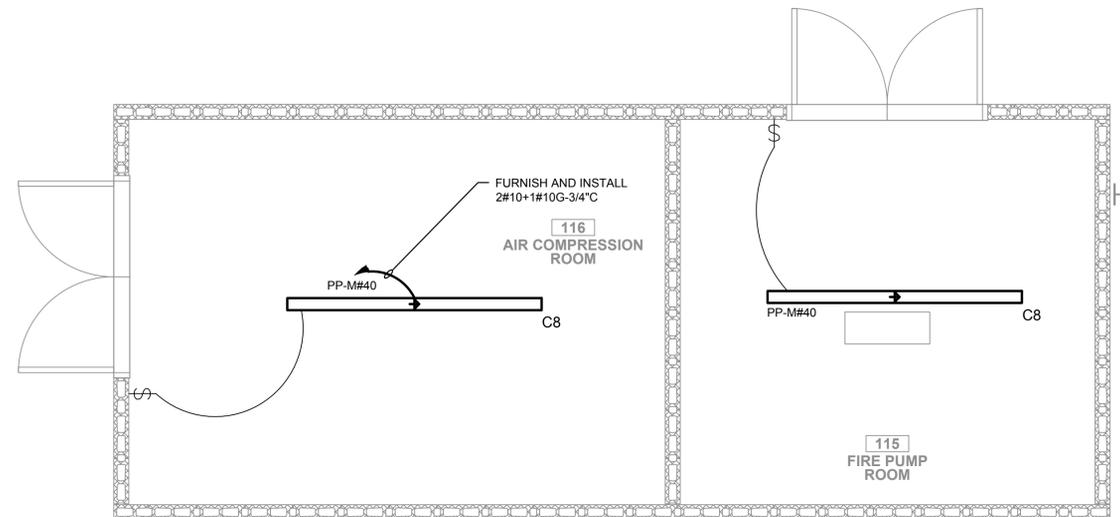

3 **ELECTRICAL LIGHTING PART PLAN - 20 DUNNIGAN AIR COMPRESSION & FIRE PUMP ROOMS**
 E-404 SCALE: 3/8" = 1'-0"

NOTES:

1. REFER TO CONTRACT DRAWING **E-001** FOR ELECTRICAL LEGEND, ABBREVIATIONS, GENERAL NOTES, AND DRAWING LIST.
2. REFER TO CONTRACT DRAWINGS **E-701**, **E-702**, AND **E-703** FOR ELECTRICAL ONE-LINE DIAGRAMS.
3. REFER TO CONTRACT DRAWING **E-607** FOR LIGHTING FIXTURE SCHEDULE.
4. REFER TO ARCHITECTURAL DRAWINGS FOR EXACT QUANTITY, LOCATION, AND SPECIFICATIONS OF LIGHTING FIXTURES.
5. REFER TO ARCHITECTURAL DRAWINGS FOR EXACT LIGHTING CONTROL SYSTEM SPECIFICATIONS, DEVICE LAYOUT, AND QUANTITY OF CONTROL DEVICES.

ARCHITECT
di Domenico + Partners LLP
 Architecture
 Landscape Architecture
 Planning
 3743 Crescent Street, 3rd Floor
 Long Island City, New York 11101
 Tel 212-337-0400
 Fax 212-337-3567

CIVIL PLANNING ENGINEER
JMC
 JMC Planning Engineering Landscape
 Architecture & Land Surveying, PLLC
 120 Bedford Road
 Armonk, New York 10504
 Tel 914-273-5225
 Fax 914-273-2102

MEP ENGINEER
Burns
 BURNS ENGINEERING, PC.
 1261 Broadway, Suite 708
 New York, New York 10001
 Tel 212-962-3503

STRUCTURAL ENGINEER
GEI
 GEI50
 1385 Broadway, 20th FL
 New York, New York 10018
 Tel 212-687-8282



MANHATTAN BEER DISTRIBUTORS
 20 DUNNIGAN DRIVE
 SUFFERN, NEW YORK

KEY PLAN

REV	DESCRIPTION	DATE
	ISSUED FOR DOB SUBMISSION	09/10/2021
	ISSUED FOR BID	10/15/2021
	ISSUED FOR PROGRESS	01/18/2022
	ISSUED FOR BID	08/30/2022

DRAWN BY : M.DIMATTIA
 CHECKED BY : B.NEMCHEK
 APPROVED BY : J.MIZRAHI
 DATE : 09/10/21
 SCALE : AS NOTED

DRAWING TITLE:
**ELECTRICAL LIGHTING PART
 PLANS - AUXILIARY ROOMS
 SHEET 1 OF 2**



TO THE BEST KNOWLEDGE, BELIEF AND PROFESSIONAL JUDGEMENT,
 THESE PLANS AND SPECIFICATIONS ARE IN COMPLIANCE WITH THE 2020
 ENERGY CONSERVATION CONSTRUCTION CODE OF NEW YORK STATE.

DWG NUMBER :
E-404