

ARCHITECT  
**di Domenico + Partners LLP**  
 Architecture  
 Landscape Architecture  
 Planning  
 3743 Crescent Street, 3rd Floor  
 Long Island City, New York 11101  
 Tel 212-337-0400  
 Fax 212-337-3567

CIVIL PLANNING ENGINEER  
**JMC**  
 JMC Planning Engineering Landscape  
 Architecture & Land Surveying, PLLC  
 120 Bedford Road  
 Armonk, New York 10504  
 Tel 914-273-5225  
 Fax 914-273-2102

MEP ENGINEER  
**Burns**  
 BURNS ENGINEERING, PC.  
 1261 Broadway, Suite 708  
 New York, New York 10001  
 Tel 212-962-3503

STRUCTURAL ENGINEER  
**GEI**  
 GEI50  
 1385 Broadway, 20th FL  
 New York, New York 10018  
 Tel 212-687-8282



**MANHATTAN BEER DISTRIBUTORS**  
 20 DUNNIGAN DRIVE  
 SUFFERN, NEW YORK

KEY PLAN

REV	DESCRIPTION	DATE
	ISSUED FOR DOB SUBMISSION	09/10/2021
	ISSUED FOR BID	10/15/2021
	ISSUED FOR PROGRESS	01/18/2022


DRAWN BY:	M.ESPINAL
CHECKED BY:	J.CLARK
APPROVED BY:	J.MIZRAHI
DATE:	04/16/21
SCALE:	1/8" = 1'-0"

DRAWING TITLE:  
**FIRE PROTECTION  
 2ND FLOOR PLAN**

DWG NUMBER:  
**F-109**

**FIRE PROTECTION NOTES**

- 1) CONTRACTOR SHALL COORDINATE WITH THE BUILDING THE SHUT DOWN OF THE FIRE STANDPIPE/SPRINKLER RISERS.
- 2) CONTRACTOR SHALL COORDINATE ROUTING OF NEW SPRINKLER PIPING WITH THE PROPOSED STRUCTURE AND ALL TRADES TO AVOID CONFLICTS.
- 3) DESIGN DRAWINGS ARE SCHEMATIC. PIPING IS SHOWN APPROXIMATELY ONLY. EXACT LOCATION MUST BE DETERMINED BY THE SPRINKLER CONTRACTOR IN THE FIELD. CONTRACTOR SHALL VISIT THE SITE PRIOR TO BIDDING OR AWARD OF CONTACT TO INSPECT EXISTING FIELD CONDITIONS. THIS CONTRACT SHALL INCLUDE ALL LABOR AND MATERIALS NECESSARY FOR FIELD MODIFICATIONS DUE TO EXISTING CONDITIONS.
- 4) THE CONTRACTOR SHALL CONTACT THE ARCHITECT, ENGINEER OR OWNER PRIOR TO BIDDING FOR INTERPRETATIONS AND CLARIFICATIONS OF THE DESIGN AND INCLUDE IN HIS BID ALL COSTS TO MEET THE DESIGN INTENT. CLARIFICATIONS MADE BY THE ARCHITECT, ENGINEER OR OWNER AFTER BIDDING WILL BE FINAL AND SHALL BE IMPLEMENTED AT CONTRACTORS COST.
- 5) BIDDING CONTRACTORS SHALL HAVE A WORKING KNOWLEDGE OF LOCAL CODES AND ORDINANCES AND SHALL INCLUDE IN THEIR BIDS THE COSTS FOR ALL WORK INSTALLED IN STRICT ACCORDANCE WITH GOVERNING CODES. THE PLANS AND SPECIFICATIONS NOT WITHSTANDING. THE CONTRACTOR SHALL ALERT ARCHITECT, ENGINEER OR OWNER OF ANY APPARENT DISCREPANCIES BETWEEN GOVERNING CODES AND DESIGN INTENT.
- 6) PROVIDE SPRINKLER HEADS BELOW ALL EXPOSED OBSTRUCTIONS OVER 48" WIDE. THIS REQUIREMENT SHALL INCLUDE DUCT WORK RUNNING PARALLEL OF EACH OTHER PRODUCING A WIDTH OF 48" AND OVER. SPRINKLER HEAD INSTALLED WHERE MINIMUM HEAD CLEARANCE IS NOT MET SHALL BE EQUIPPED WITH WIRE GUARD COVERS.
- 7) PIPES SIZES SHOWN ARE BASED ON DESIGN PIPING LAYOUTS ONLY. ACTUAL PIPE SIZES SHALL BE DETERMINED BY CONTRACTORS HYDRAULIC CALCULATIONS BASED ON HIS INSTALLATION DRAWINGS. CONTRACTOR SHALL ALLOW FOR THIS AND INCLUDE THIS IN HIS CONTRACT PRICE.

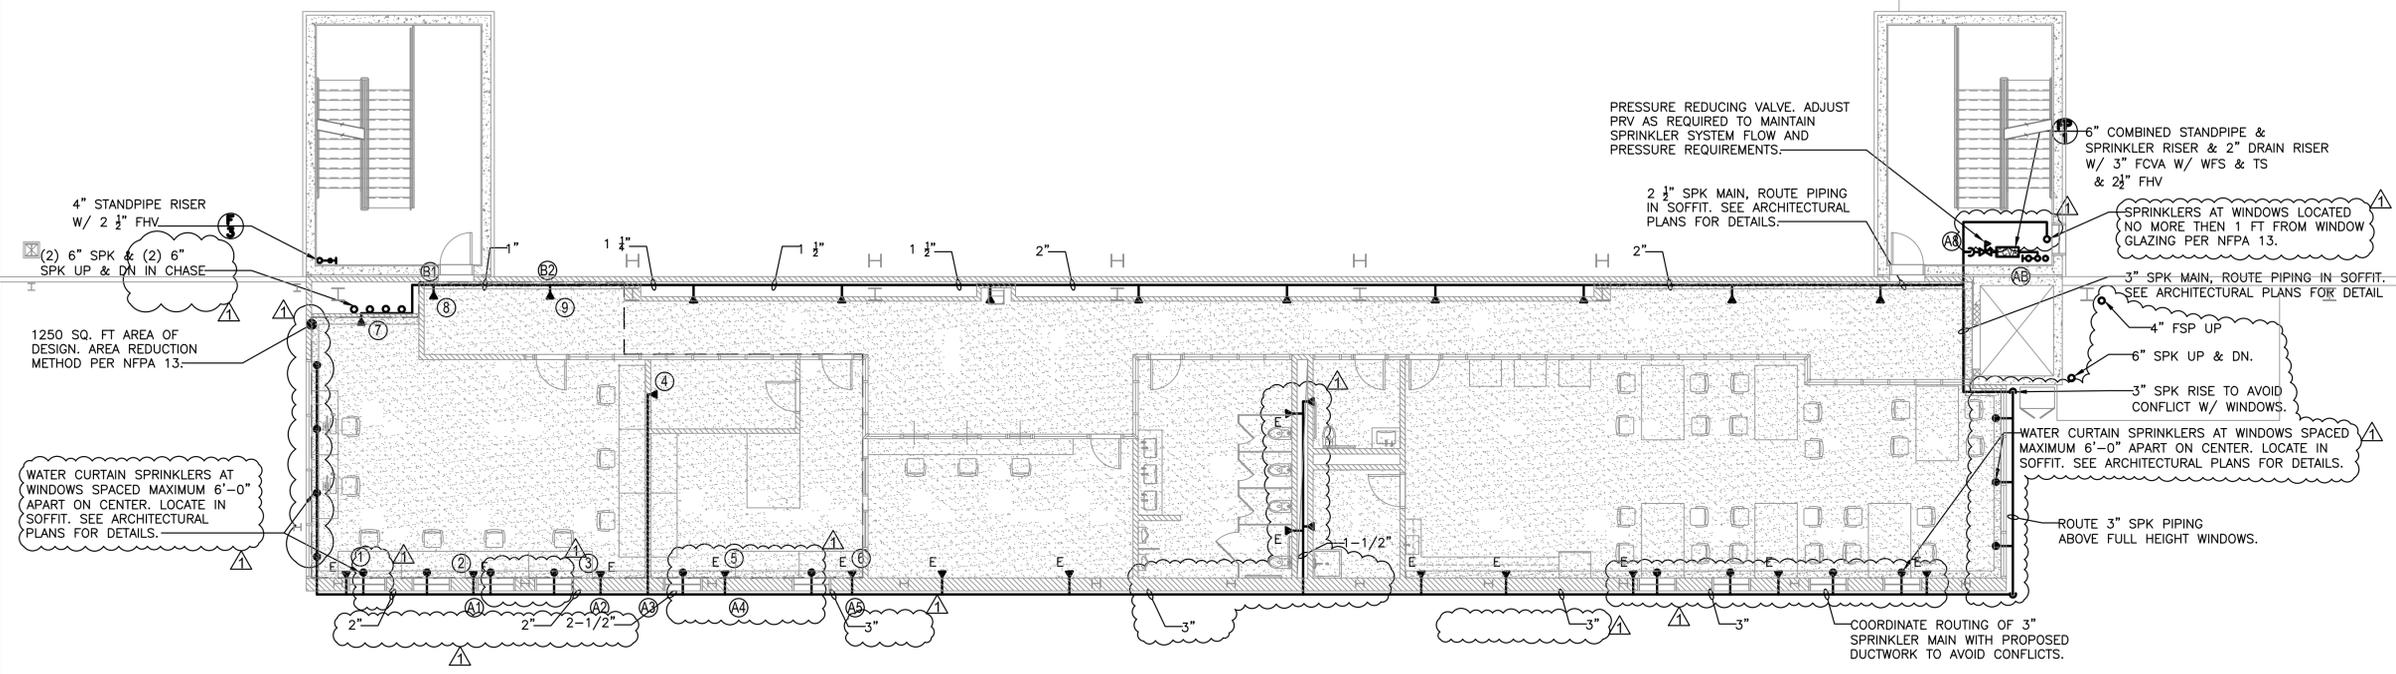

TO THE BEST KNOWLEDGE, BELIEF AND PROFESSIONAL JUDGEMENT, THESE PLANS AND SPECIFICATIONS ARE IN COMPLIANCE WITH THE 2020 ENERGY CONSERVATION CONSTRUCTION CODE OF NEW YORK STATE.