




D	
	DEVISIONS


ISSUED: BID SET ISSUANCE


OVERALL FIRST FLOOR

PROJECT NUMBER: 2111002.00 COPYRIGHT © 2014 KSQ ARCHITECTS, PC

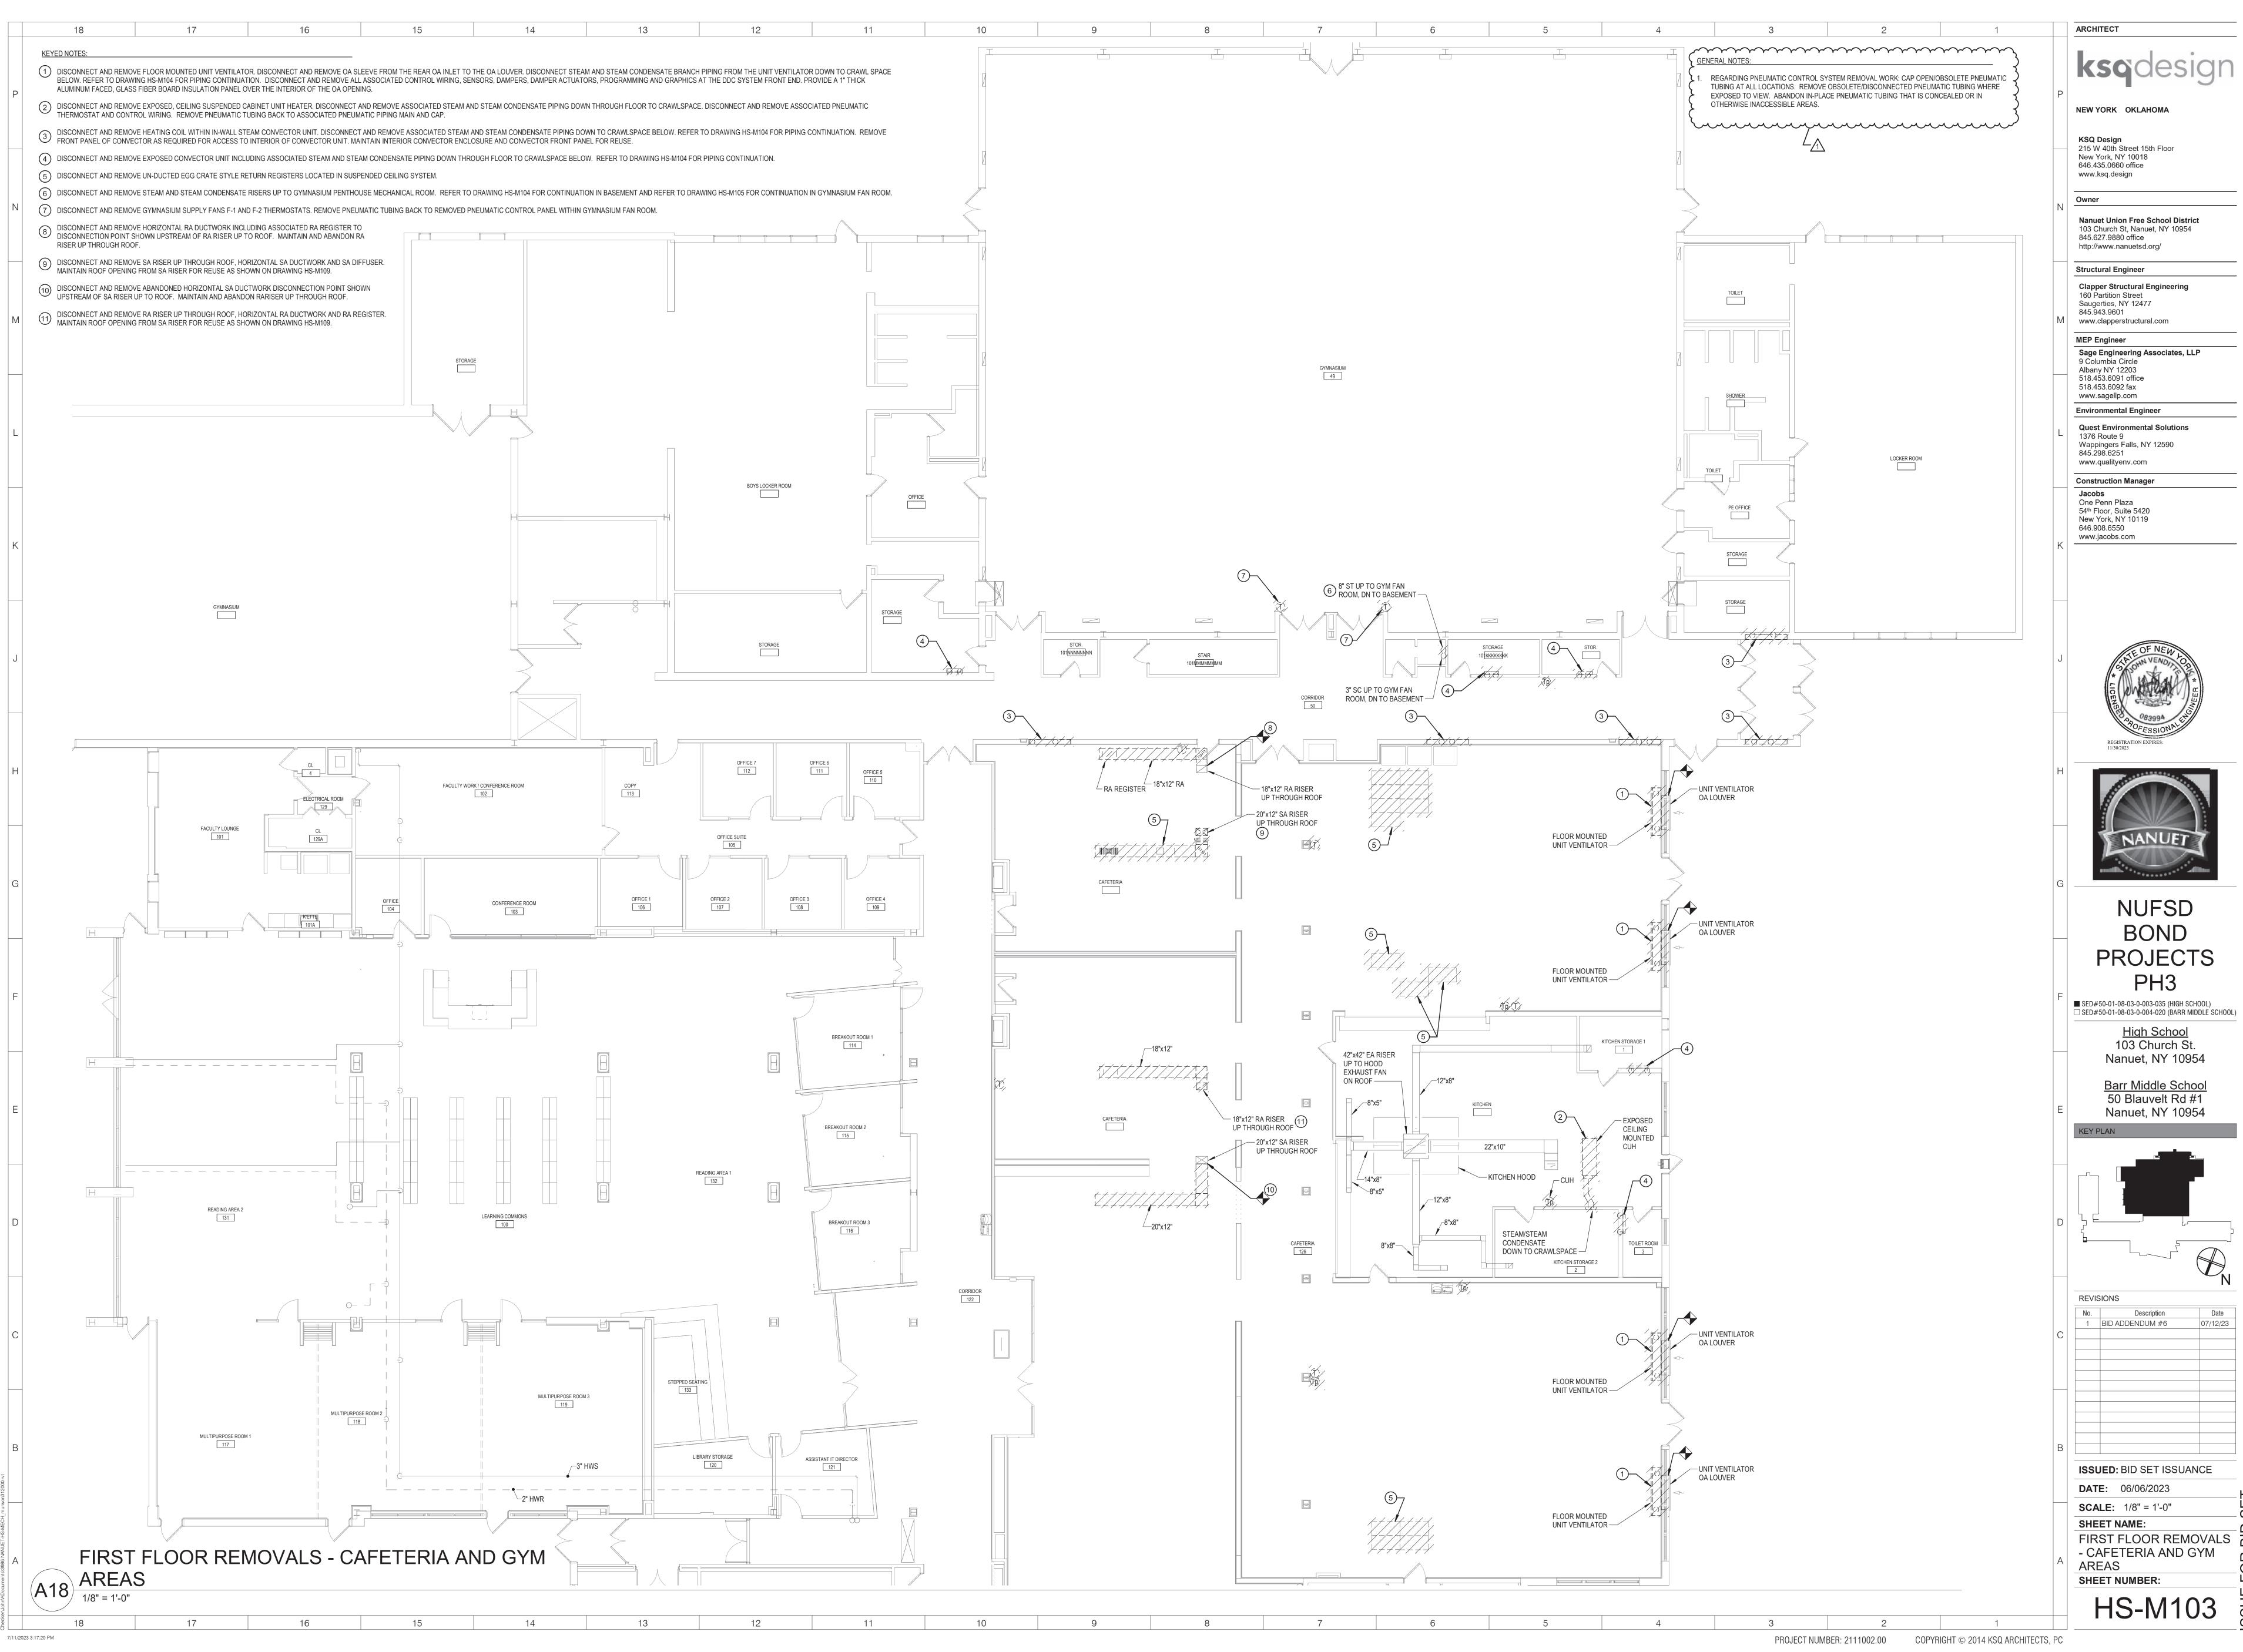



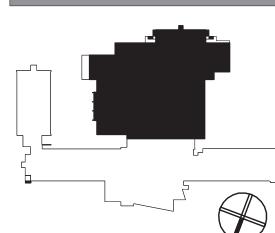

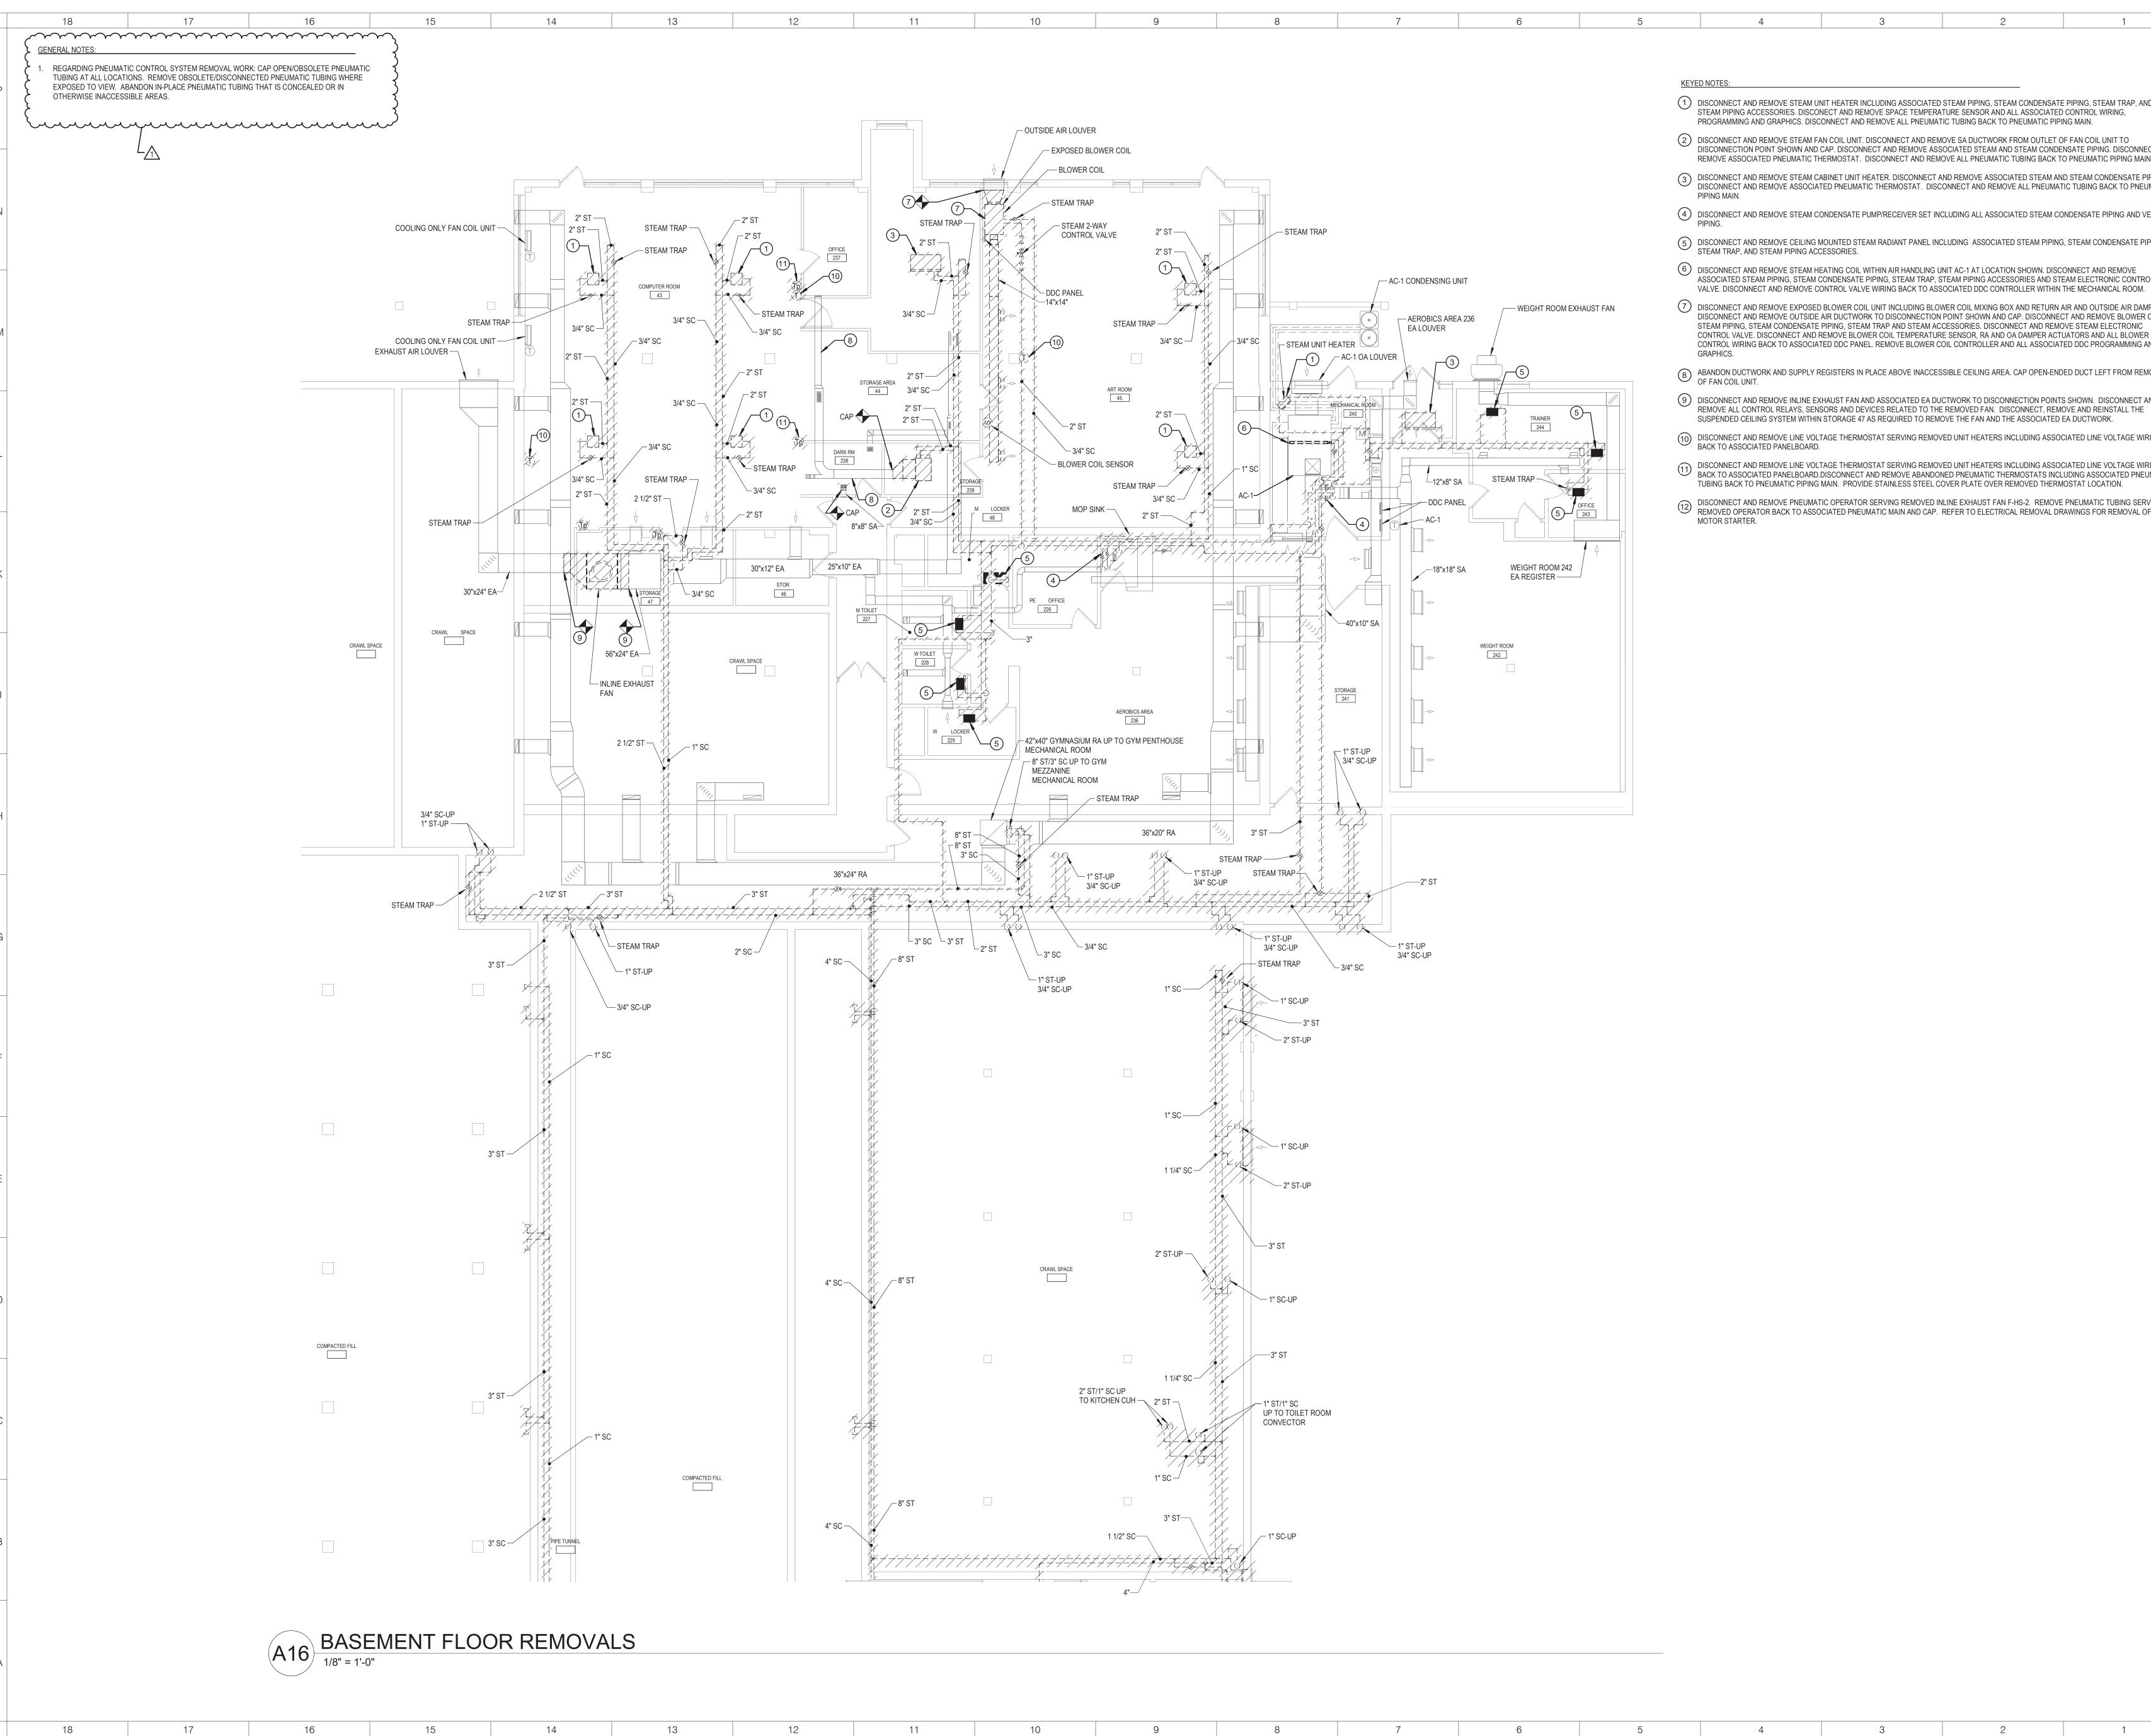

7/11/2023 3:17:21 PM

- 1) DISCONNECT AND REMOVE STEAM UNIT HEATER INCLUDING ASSOCIATED STEAM PIPING, STEAM CONDENSATE PIPING, STEAM TRAP, AND STEAM PIPING ACCESSORIES. DISCONECT AND REMOVE SPACE TEMPERATURE SENSOR AND ALL ASSOCIATED CONTROL WIRING, PROGRAMMING AND GRAPHICS. DISCONNECT AND REMOVE ALL PNEUMATIC TUBING BACK TO PNEUMATIC PIPING MAIN.
- (2) DISCONNECT AND REMOVE STEAM FAN COIL UNIT. DISCONNECT AND REMOVE SA DUCTWORK FROM OUTLET OF FAN COIL UNIT TO DISCONNECTION POINT SHOWN AND CAP. DISCONNECT AND REMOVE ASSOCIATED STEAM AND STEAM CONDENSATE PIPING. DISCONNECT AND
- REMOVE ASSOCIATED PNEUMATIC THERMOSTAT. DISCONNECT AND REMOVE ALL PNEUMATIC TUBING BACK TO PNEUMATIC PIPING MAIN. (3) DISCONNECT AND REMOVE STEAM CABINET UNIT HEATER. DISCONNECT AND REMOVE ASSOCIATED STEAM AND STEAM CONDENSATE PIPING. DISCONNECT AND REMOVE ASSOCIATED PNEUMATIC THERMOSTAT. DISCONNECT AND REMOVE ALL PNEUMATIC TUBING BACK TO PNEUMATIC
- DISCONNECT AND REMOVE STEAM CONDENSATE PUMP/RECEIVER SET INCLUDING ALL ASSOCIATED STEAM CONDENSATE PIPING AND VENT
- DISCONNECT AND REMOVE CEILING MOUNTED STEAM RADIANT PANEL INCLUDING ASSOCIATED STEAM PIPING, STEAM CONDENSATE PIPING, STEAM TRAP, AND STEAM PIPING ACCESSORIES.
- (6) DISCONNECT AND REMOVE STEAM HEATING COIL WITHIN AIR HANDLING UNIT AC-1 AT LOCATION SHOWN. DISCONNECT AND REMOVE ASSOCIATED STEAM PIPING, STEAM CONDENSATE PIPING, STEAM TRAP, STEAM PIPING ACCESSORIES AND STEAM ELECTRONIC CONTROL
- 7 DISCONNECT AND REMOVE EXPOSED BLOWER COIL UNIT INCLUDING BLOWER COIL MIXING BOX AND RETURN AIR AND OUTSIDE AIR DAMPERS. DISCONNECT AND REMOVE OUTSIDE AIR DUCTWORK TO DISCONNECTION POINT SHOWN AND CAP. DISCONNECT AND REMOVE BLOWER COIL STEAM PIPING, STEAM CONDENSATE PIPING, STEAM TRAP AND STEAM ACCESSORIES, DISCONNECT AND REMOVE STEAM ELECTRONIC CONTROL VALVE. DISCONNECT AND REMOVE BLOWER COIL TEMPERATURE SENSOR, RA AND OA DAMPER ACTUATORS AND ALL BLOWER COIL CONTROL WIRING BACK TO ASSOCIATED DDC PANEL. REMOVE BLOWER COIL CONTROLLER AND ALL ASSOCIATED DDC PROGRAMMING AND
- ABANDON DUCTWORK AND SUPPLY REGISTERS IN PLACE ABOVE INACCESSIBLE CEILING AREA. CAP OPEN-ENDED DUCT LEFT FROM REMOVAL OF FAN COIL UNIT.
- (9) DISCONNECT AND REMOVE INLINE EXHAUST FAN AND ASSOCIATED EA DUCTWORK TO DISCONNECTION POINTS SHOWN. DISCONNECT AND REMOVE ALL CONTROL RELAYS, SENSORS AND DEVICES RELATED TO THE REMOVED FAN. DISCONNECT, REMOVE AND REINSTALL THE SUSPENDED CEILING SYSTEM WITHIN STORAGE 47 AS REQUIRED TO REMOVE THE FAN AND THE ASSOCIATED EA DUCTWORK.
- DISCONNECT AND REMOVE LINE VOLTAGE THERMOSTAT SERVING REMOVED UNIT HEATERS INCLUDING ASSOCIATED LINE VOLTAGE WIRING BACK TO ASSOCIATED PANELBOARD.
- DISCONNECT AND REMOVE LINE VOLTAGE THERMOSTAT SERVING REMOVED UNIT HEATERS INCLUDING ASSOCIATED LINE VOLTAGE WIRING BACK TO ASSOCIATED PANELBOARD.DISCONNECT AND REMOVE ABANDONED PNEUMATIC THERMOSTATS INCLUDING ASSOCIATED PNEUMATIC TUBING BACK TO PNEUMATIC PIPING MAIN. PROVIDE STAINLESS STEEL COVER PLATE OVER REMOVED THERMOSTAT LOCATION.
- DISCONNECT AND REMOVE PNEUMATIC OPERATOR SERVING REMOVED INLINE EXHAUST FAN F-HS-2. REMOVE PNEUMATIC TUBING SERVING REMOVED OPERATOR BACK TO ASSOCIATED PNEUMATIC MAIN AND CAP. REFER TO ELECTRICAL REMOVAL DRAWINGS FOR REMOVAL OF F-HS-2

NEW YORK OKLAHOMA

ARCHITECT

KSQ Design 215 W 40th Street 15th Floor New York, NY 10018 646.435.0660 office

www.ksq.design

Owner

Nanuet Union Free School District 103 Church St, Nanuet, NY 10954 845.627.9880 office

http://www.nanuetsd.org/

Structural Engineer Clapper Structural Engineering 160 Partition Street

Saugerties, NY 12477

845.943.9601 www.clapperstructural.com

MEP Engineer Sage Engineering Associates, LLP 9 Columbia Circle Albany NY 12203

518.453.6091 office 518.453.6092 fax www.sagellp.com **Environmental Engineer**

Quest Environmental Solutions 1376 Route 9 Wappingers Falls, NY 12590 845.298.6251

www.qualityenv.com **Construction Manager** One Penn Plaza 54th Floor, Suite 5420 New York, NY 10119

646.908.6550 www.jacobs.com





NUFSD BOND **PROJECTS** PH3

■ SED#50-01-08-03-0-003-035 (HIGH SCH00L)

□ SED#50-01-08-03-0-004-020 (BARR MIDDLE SCH00L)

High School 103 Church St. Nanuet, NY 10954


Barr Middle School 50 Blauvelt Rd #1 Nanuet, NY 10954

ISSUED: BID SET ISSUANCE

DATE: 06/06/2023 **SCALE**: 1/8" = 1'-0"

SHEET NAME: BASEMENT HVAC REMOVALS

SHEET NUMBER: HS-M104

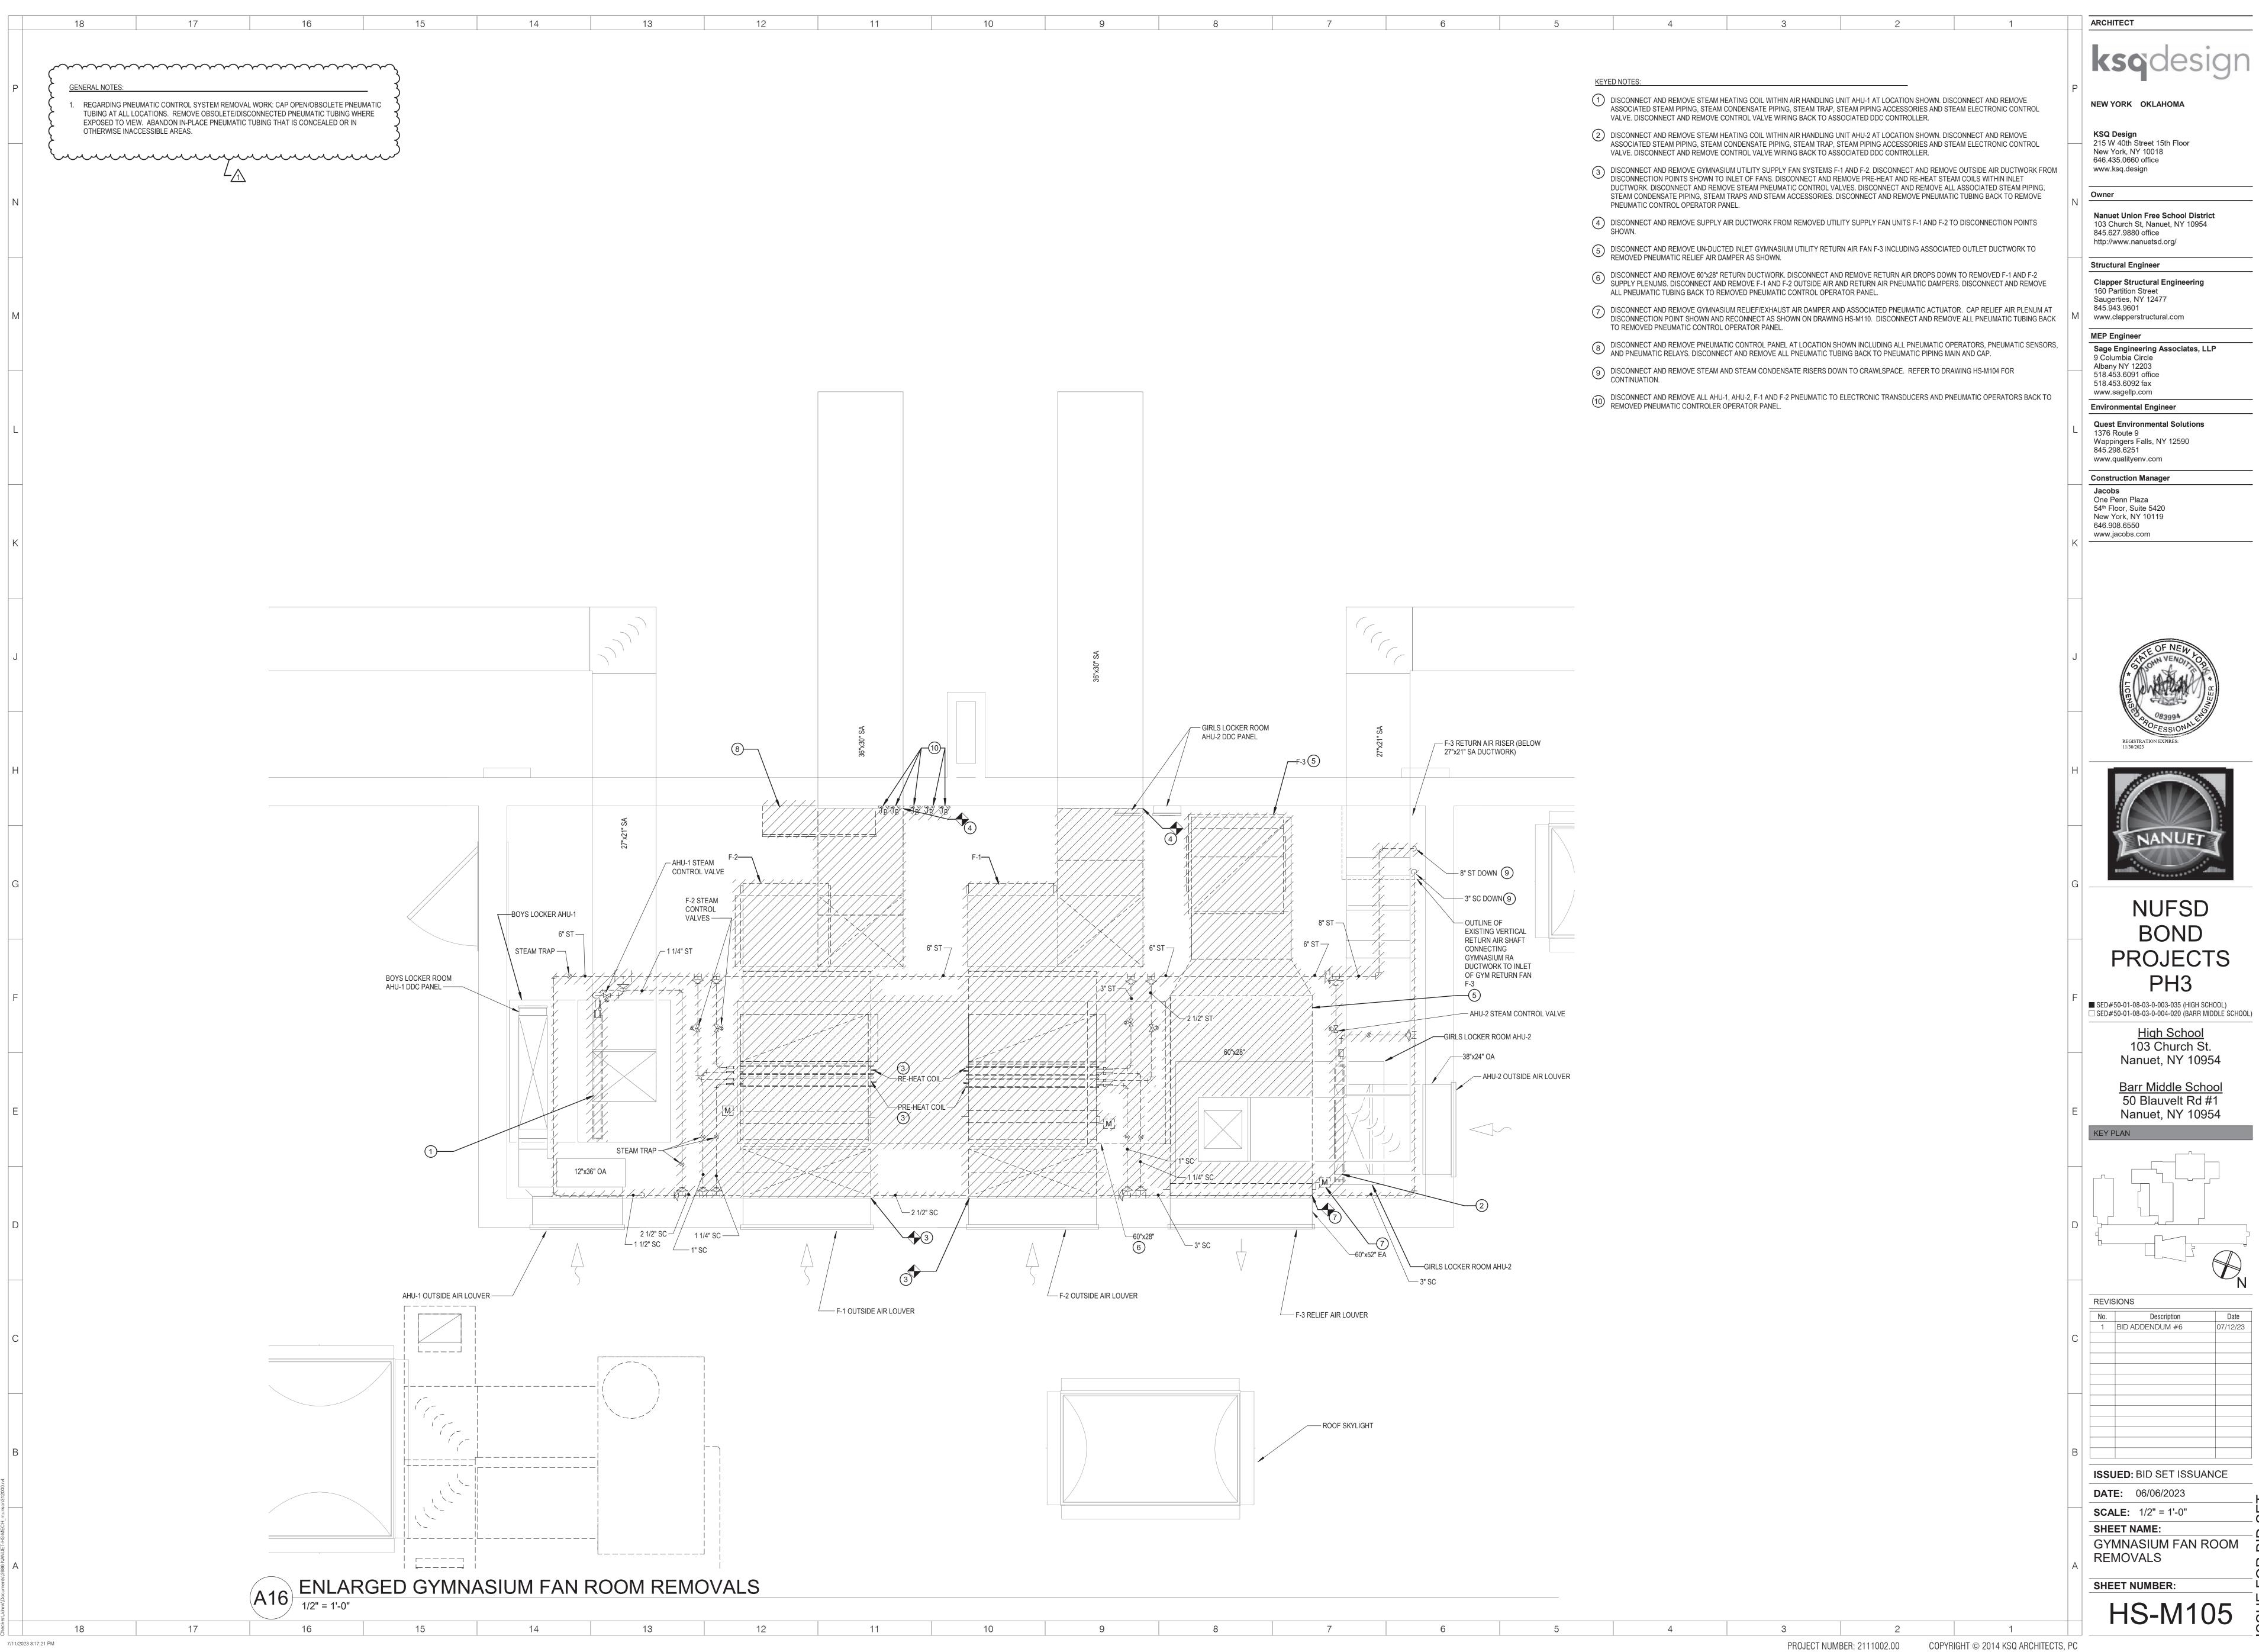


Nanuet Union Free School District





PROJECTS

Barr Middle School

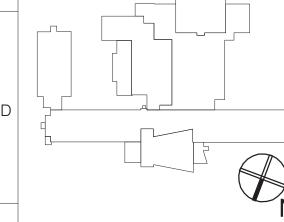

	No.	Description	Da
	1	BID ADDENDUM #6	07/12
,			

HS-M105