


18 17 16 15 14 13 12 11 10 9 8 7 6 5 4 3 2 1

- KEYED NOTES:**
- ① LIQUID OUTDOOR MULTI-CONNECTION PIPING KIT.
 - ② SUCTION OUTDOOR MULTI-CONNECTION PIPING KIT.
 - ③ MOUNT HEAT PUMP HP-ME-7 ON TOP OF ROOF MOUNTED STEEL DUNNAGE 18" ABOVE ROOF SURFACE. COORDINATE FIXING HEAT PUMP TO TOP OF DUNNAGE WITH MANUFACTURER AS REQUIRED.

- GENERAL NOTES:**
1. REFRIGERANT PIPING NOTE: THE HEAT PUMP SYSTEM MANUFACTURER SHALL INSPECT ALL FIELD INSTALLED REFRIGERANT PIPING PRIOR TO INSULATION INSTALLATION.
 2. ALL ROOFING WORK REQUIRED TO COMPLETE THE MECHANICAL INSTALLATION WORK SHALL BE BY THE MECHANICAL CONTRACTOR. ALL ROOFING WORK SHALL BE DONE AS TO MAINTAIN THE EXISTING ROOFING WARRANTY.
 3. ROUTE REFRIGERANT PIPING THROUGH THE ROOF TO THE ROOF MOUNTED HEAT PUMP SYSTEMS. PROVIDE A PIPE CURB AND SIDE REFRIGERANT PIPING OUTLET PORTAL AT THE ROOF PENETRATION OF EACH HEAT PUMP SYSTEM.
 4. PROVIDE EQUIPMENT SUPPORT ROOF CURBS AND VIBRATION ISOLATION RAILS FOR MOUNTING OF THE HEAT PUMP TO THE ROOF PER SPECIFICATION SECTION 238129. MOUNT HEAT PUMPS 24" ABOVE ROOF SURFACE.
 5. PROVIDE INSULATION AND INSULATION PROTECTION SYSTEM AROUND ALL ROOFTOP REFRIGERANT PIPING PER SPECIFICATION SECTION 230719.

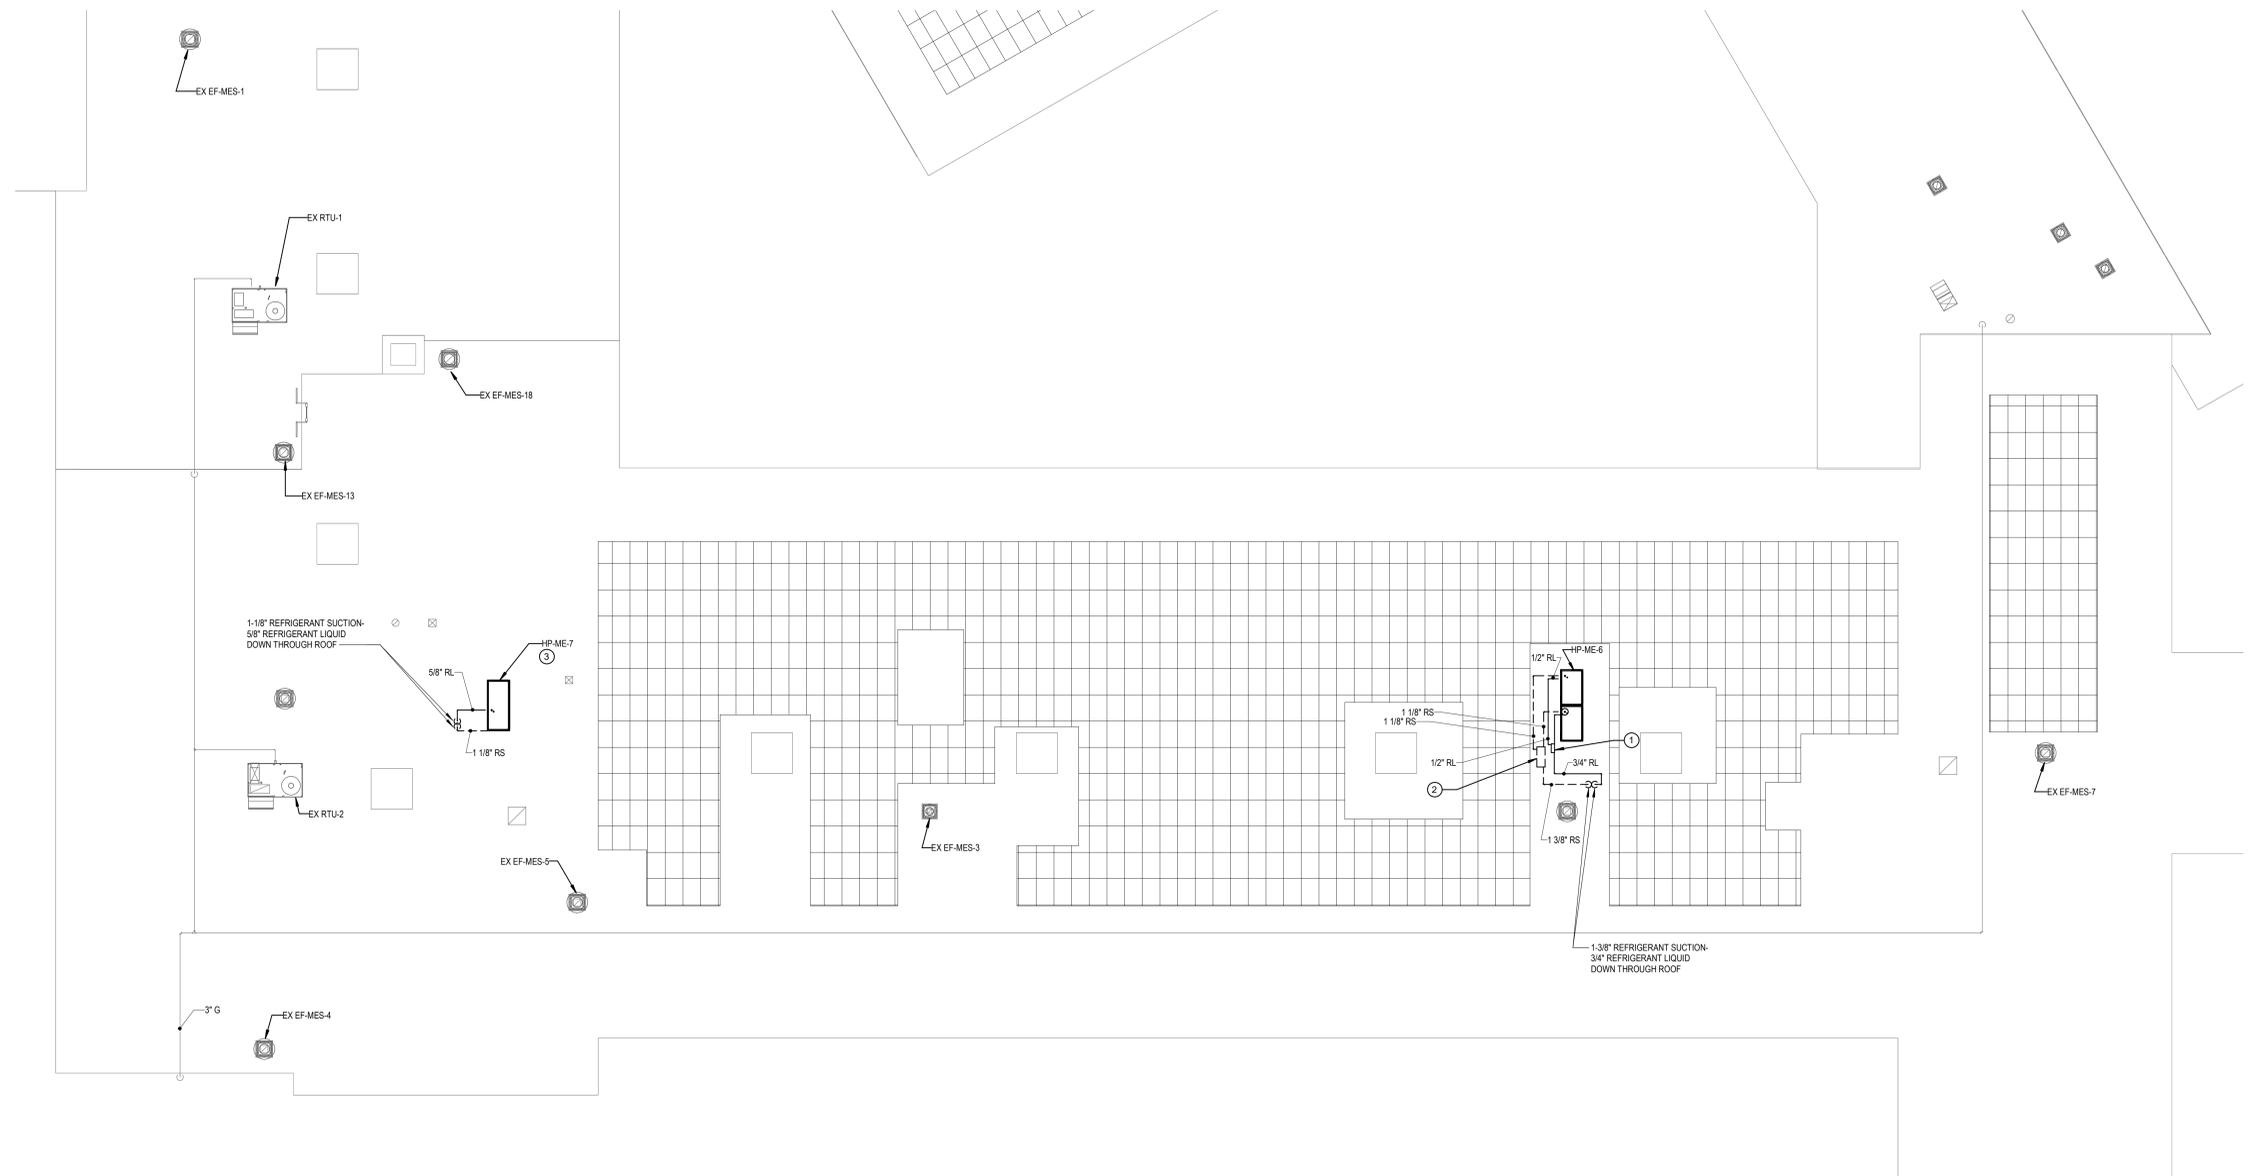

PARTIAL ROOF PLAN - KINDERGARTEN WING A1
1/8" = 1'-0"

ARCHITECT



NEW YORK OKLAHOMA

KSQ Design
215 W 40th Street 15th Floor
New York, NY 10018
646.435.0660 office
www.ksqdesign.com

Owner

Nanuet Union Free School District
101 Church Street
Nanuet, NY 10954
845.627.9880
www.nanuetd.org

Structural Engineer

Clapper Structural Engineering
160 Partition Street
Saugerties, NY 12477
845.943.9511
www.clappersstructural.com

MEP Engineer

Sage Engineering Associates, LLP
9 Columbia Circle
Albany, NY 12203
518.453.6091
www.sagegrp.com

Environmental Engineer

Quest Environmental Solutions
1376 Route 9
Wappingers Falls, NY 12590
845.298.6251
www.qualityenv.com

Construction Manager

Jacobs
One Penn Plaza
24th Floor, Suite 2400
New York, NY 10119
646.906.6550
www.jacobs.com



**NUFSD BOND PROJECTS
PHASE 5 -
MILLER ES**

- SED#50-01-08-03-0-002-020 (HIGHVIEW ES)
- SED#50-01-08-03-7-001-002 (Maintenance)
- SED#50-01-08-03-7-012-004 (OEC)
- SED#50-01-08-03-0-001-028 (MILLER ES)
- SED#50-01-08-03-0-004-022 (BARR MS)

Highview Elementary School
24 Highview Ave
Nanuet, NY 10954

OEC Building
135 Convent Rd
Nanuet, NY 10954

Maintenance Building
103 Church St.
Nanuet, NY 10954

Miller Elementary School
50 Blauvelt Rd Unit 1
Nanuet, NY 10954

A MacArthur Barr Middle School
143 Church St
Nanuet, NY 10954

KEY PLAN

REVISIONS

No.	Description	Date
1	BID ADDENDUM #4	02/05/25

ISSUED: BID SET

DATE: 06/21/2024

SCALE: 1/8" = 1'-0"

SHEET NAME:
PARTIAL ROOF PLAN -
KINDERGARTEN WING

SHEET NUMBER:

ME-M106

ISSUE FOR BID SET

2/4/2025 9:11:31 AM

18 17 16 15 14 13 12 11 10 9 8 7 6 5 4 3 2 1