

NOTE: SEE CIVIL DRAWINGS FOR GRADING AND DRAINAGE

KEY PLAN

RETAINING WALL - SEE CIVIL PLANS

BROADVIEW

SENIOR LIVING AT PURCHASE COLLEGE Westchester County, New York

735 Anderson Hill Road Purchase, NY 10577-1402

PLANNER, CIVIL ENGINEER

Divney Tung Schwalbe, LLP One North Broadway White Plains, NY 10601

P: 914.428.0010 F: 914.428.0017

DEVELOPER

<u>ARCHITECT</u>

HCM Design, Inc. 750 East Pratt Street Baltimore, MD 21202

39 Park Avenue Rutherford, NJ 07070

SURVEYOR

21 Fox Street

LCS DEVELOPMENT

Des Moine, IA 50309

400 Locust Street, Suite 820

LANDSCAPE ARCHITECT

MKW and Associates, LLC

THE CHAZEN COMPANIES

WETLAND CONSULTANT

195 Tunxis Hill Cutoff South

Fairfield, CT 06825

WILLIAM KENNY ASSOCIATES LLC

Poughkeepsie, NY 12601

DIVNEY • TUNG • SCHWALBE

Purchase College Learning Corporation

SPONSOR

NOTE: ALL SITE DESIGN CONCEPTS AND INFORMATION INDICATED OR REPRESENTED BY THIS DRAWING ARE OWNED BY AND ARE THE PROPERTY OF DIVNEY TUNG SCHWALBE, LLP. THIS DRAWING WAS CREATED AND DEVELOPED FOR USE ON, AND IN CONNECTION WITH, THE SPECIFIED PROJECT INDICATED HEREON AND SHALL NOT BE USED BY OR DISCLOSED TO ANY PERSON OR ENTITY WHATSOEVER WITHOUT THE WRITTEN PERMISSION OF DIVNEY TUNG SCHWALBE, LLP.

WRITTEN DIMENSIONS ON THIS DRAWING SHALL HAVE PRECEDENCE OVER SCALED MEASUREMENTS. CONTRACTOR SHALL VERIFY AND BE RESPONSIBLE FOR ALL DIMENSIONS AND CONDITIONS ON THE JOB AND THIS OFFICE MUST BE NOTIFIED OF ANY VARIATIONS FROM DIMENSIONS AND CONDITIONS SHOWN BY THESE DRAWINGS.


LEGAL NOTICE: IT IS A VIOLATION OF ARTICLE 145 OF THE NEW YORK STATE EDUCATION LAW FOR ANY PERSON TO ALTER THIS DOCUMENT IN ANY WAY EXCEPT AS PROVIDED IN SECTION 7209 (2), ARTICLE 145, NEW YORK STATE EDUCATION LAW.

© Copyright Divney Tung Schwalbe, LLP 2019 All rights reserved.


OVERALL LAYOUT & MATERIALS PLAN 1 OF 6



L101 SCALE: 1" = 300'

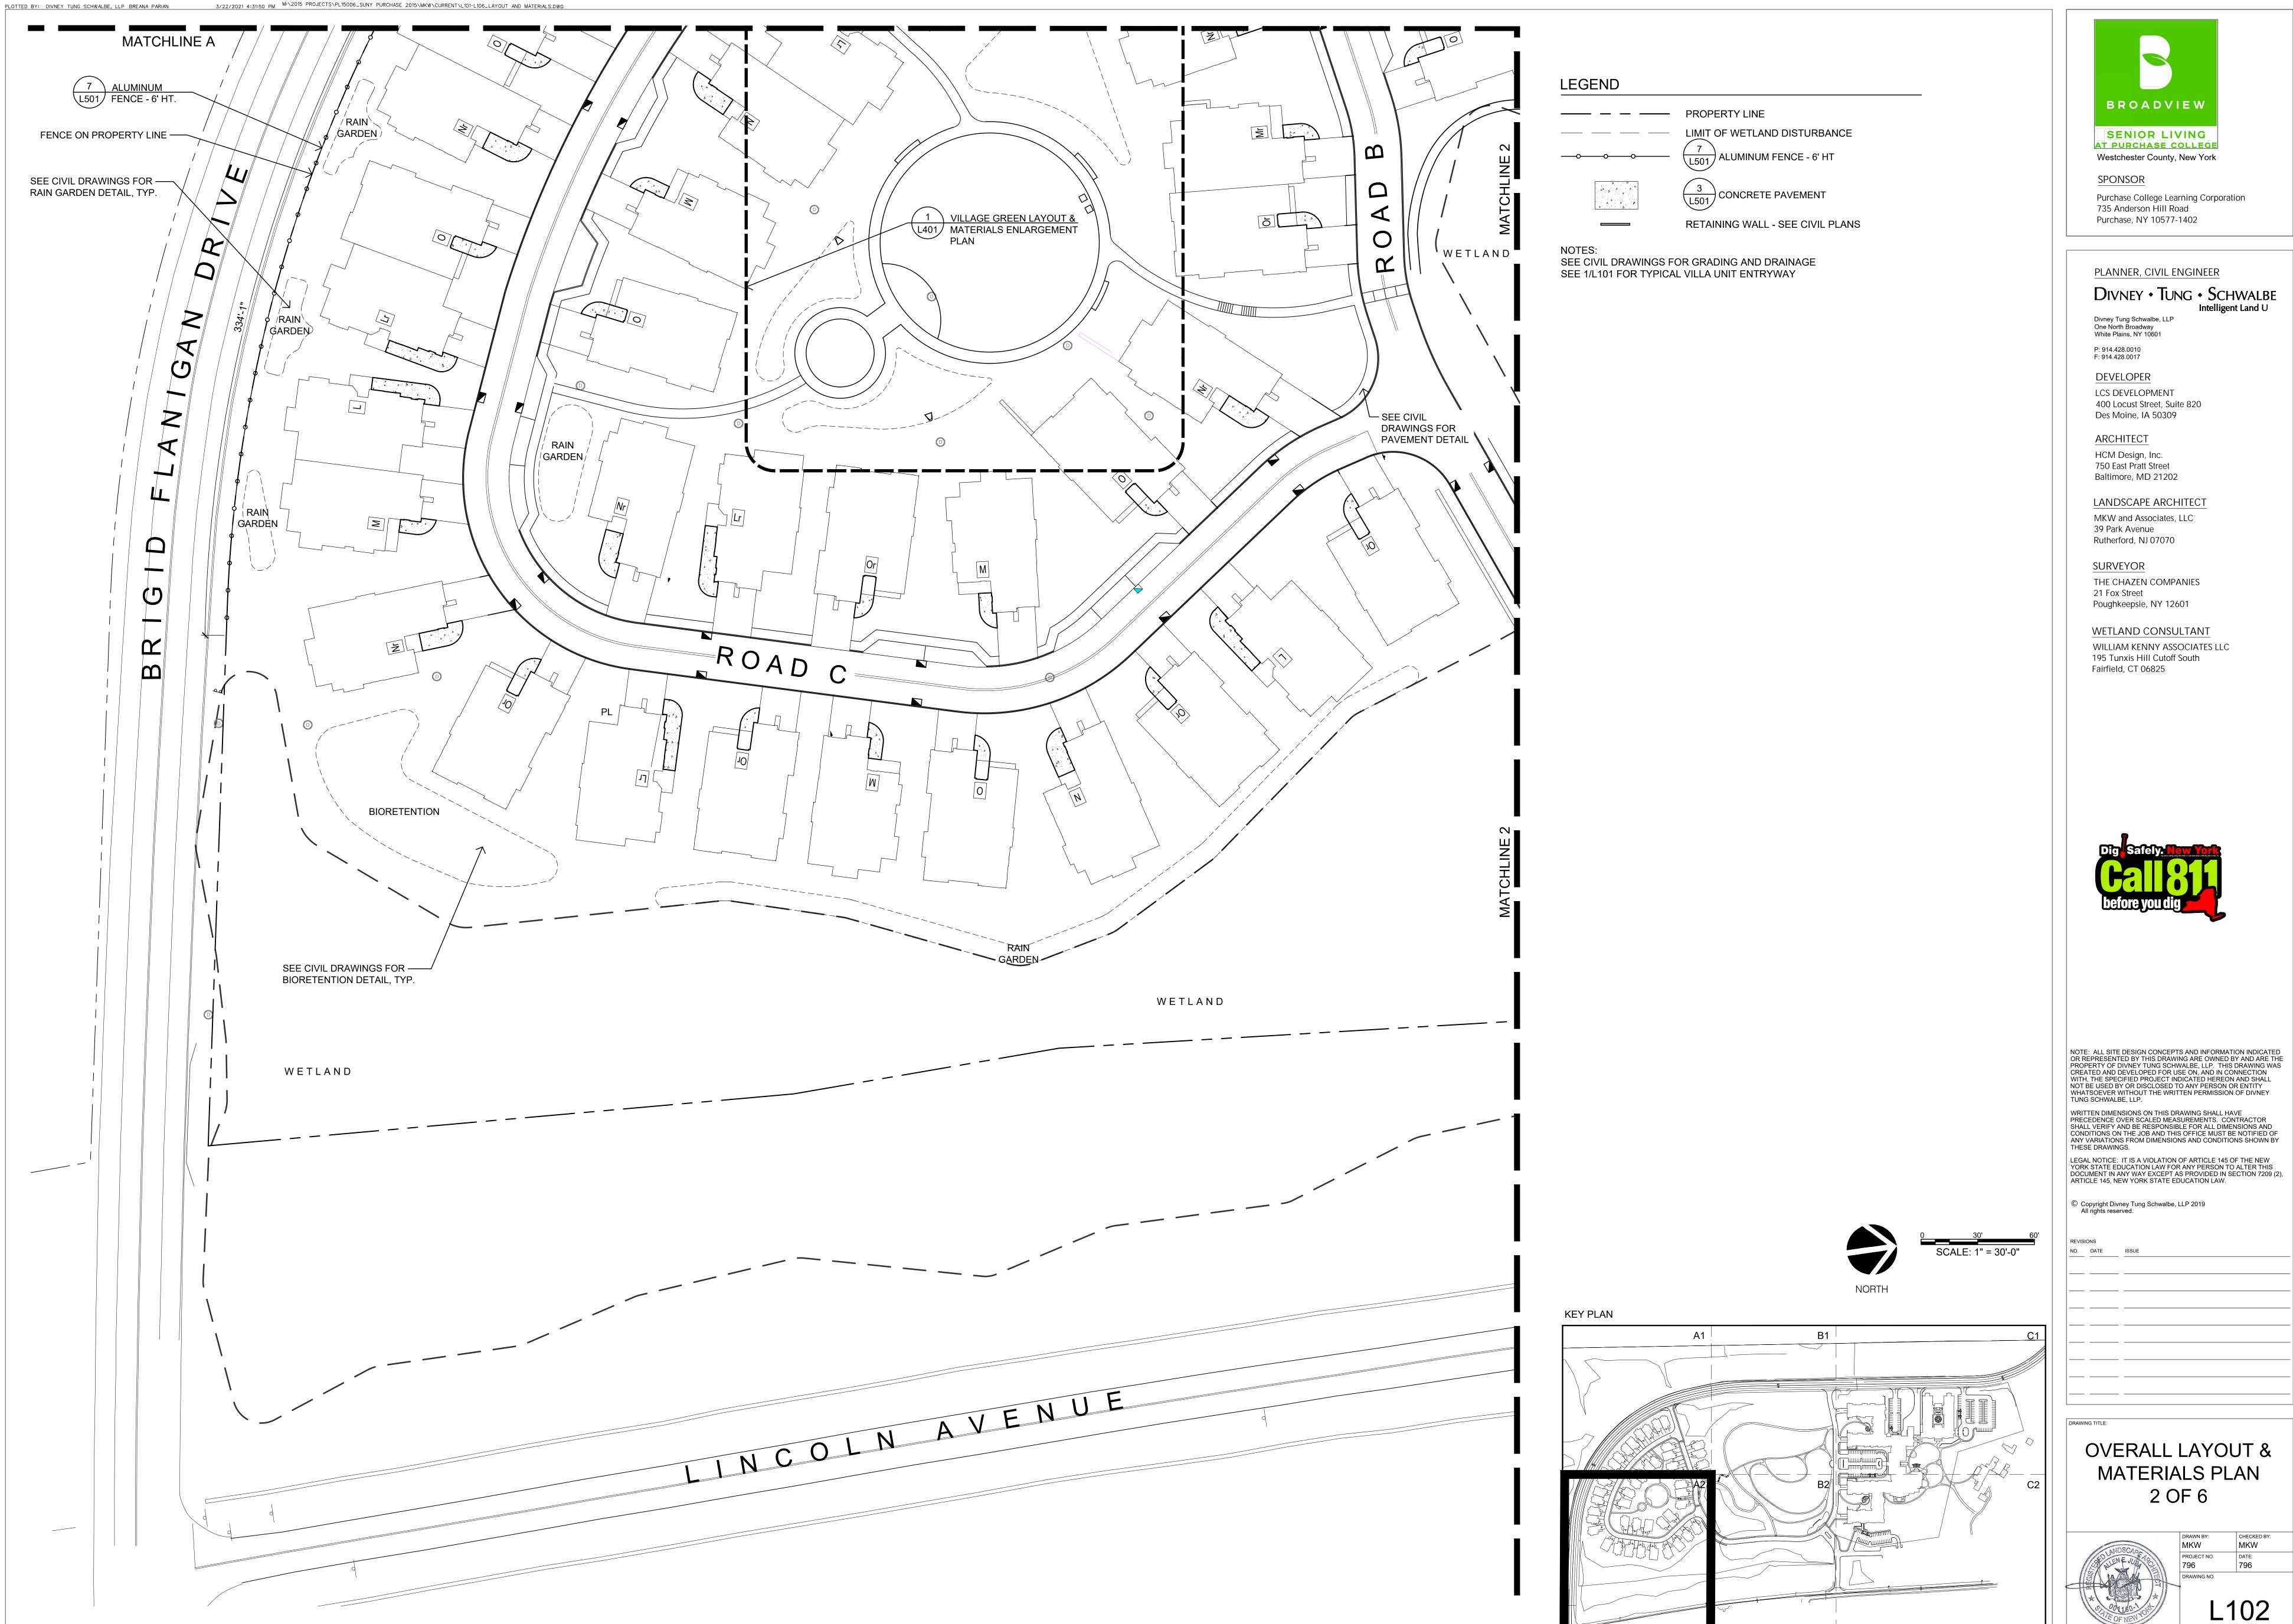



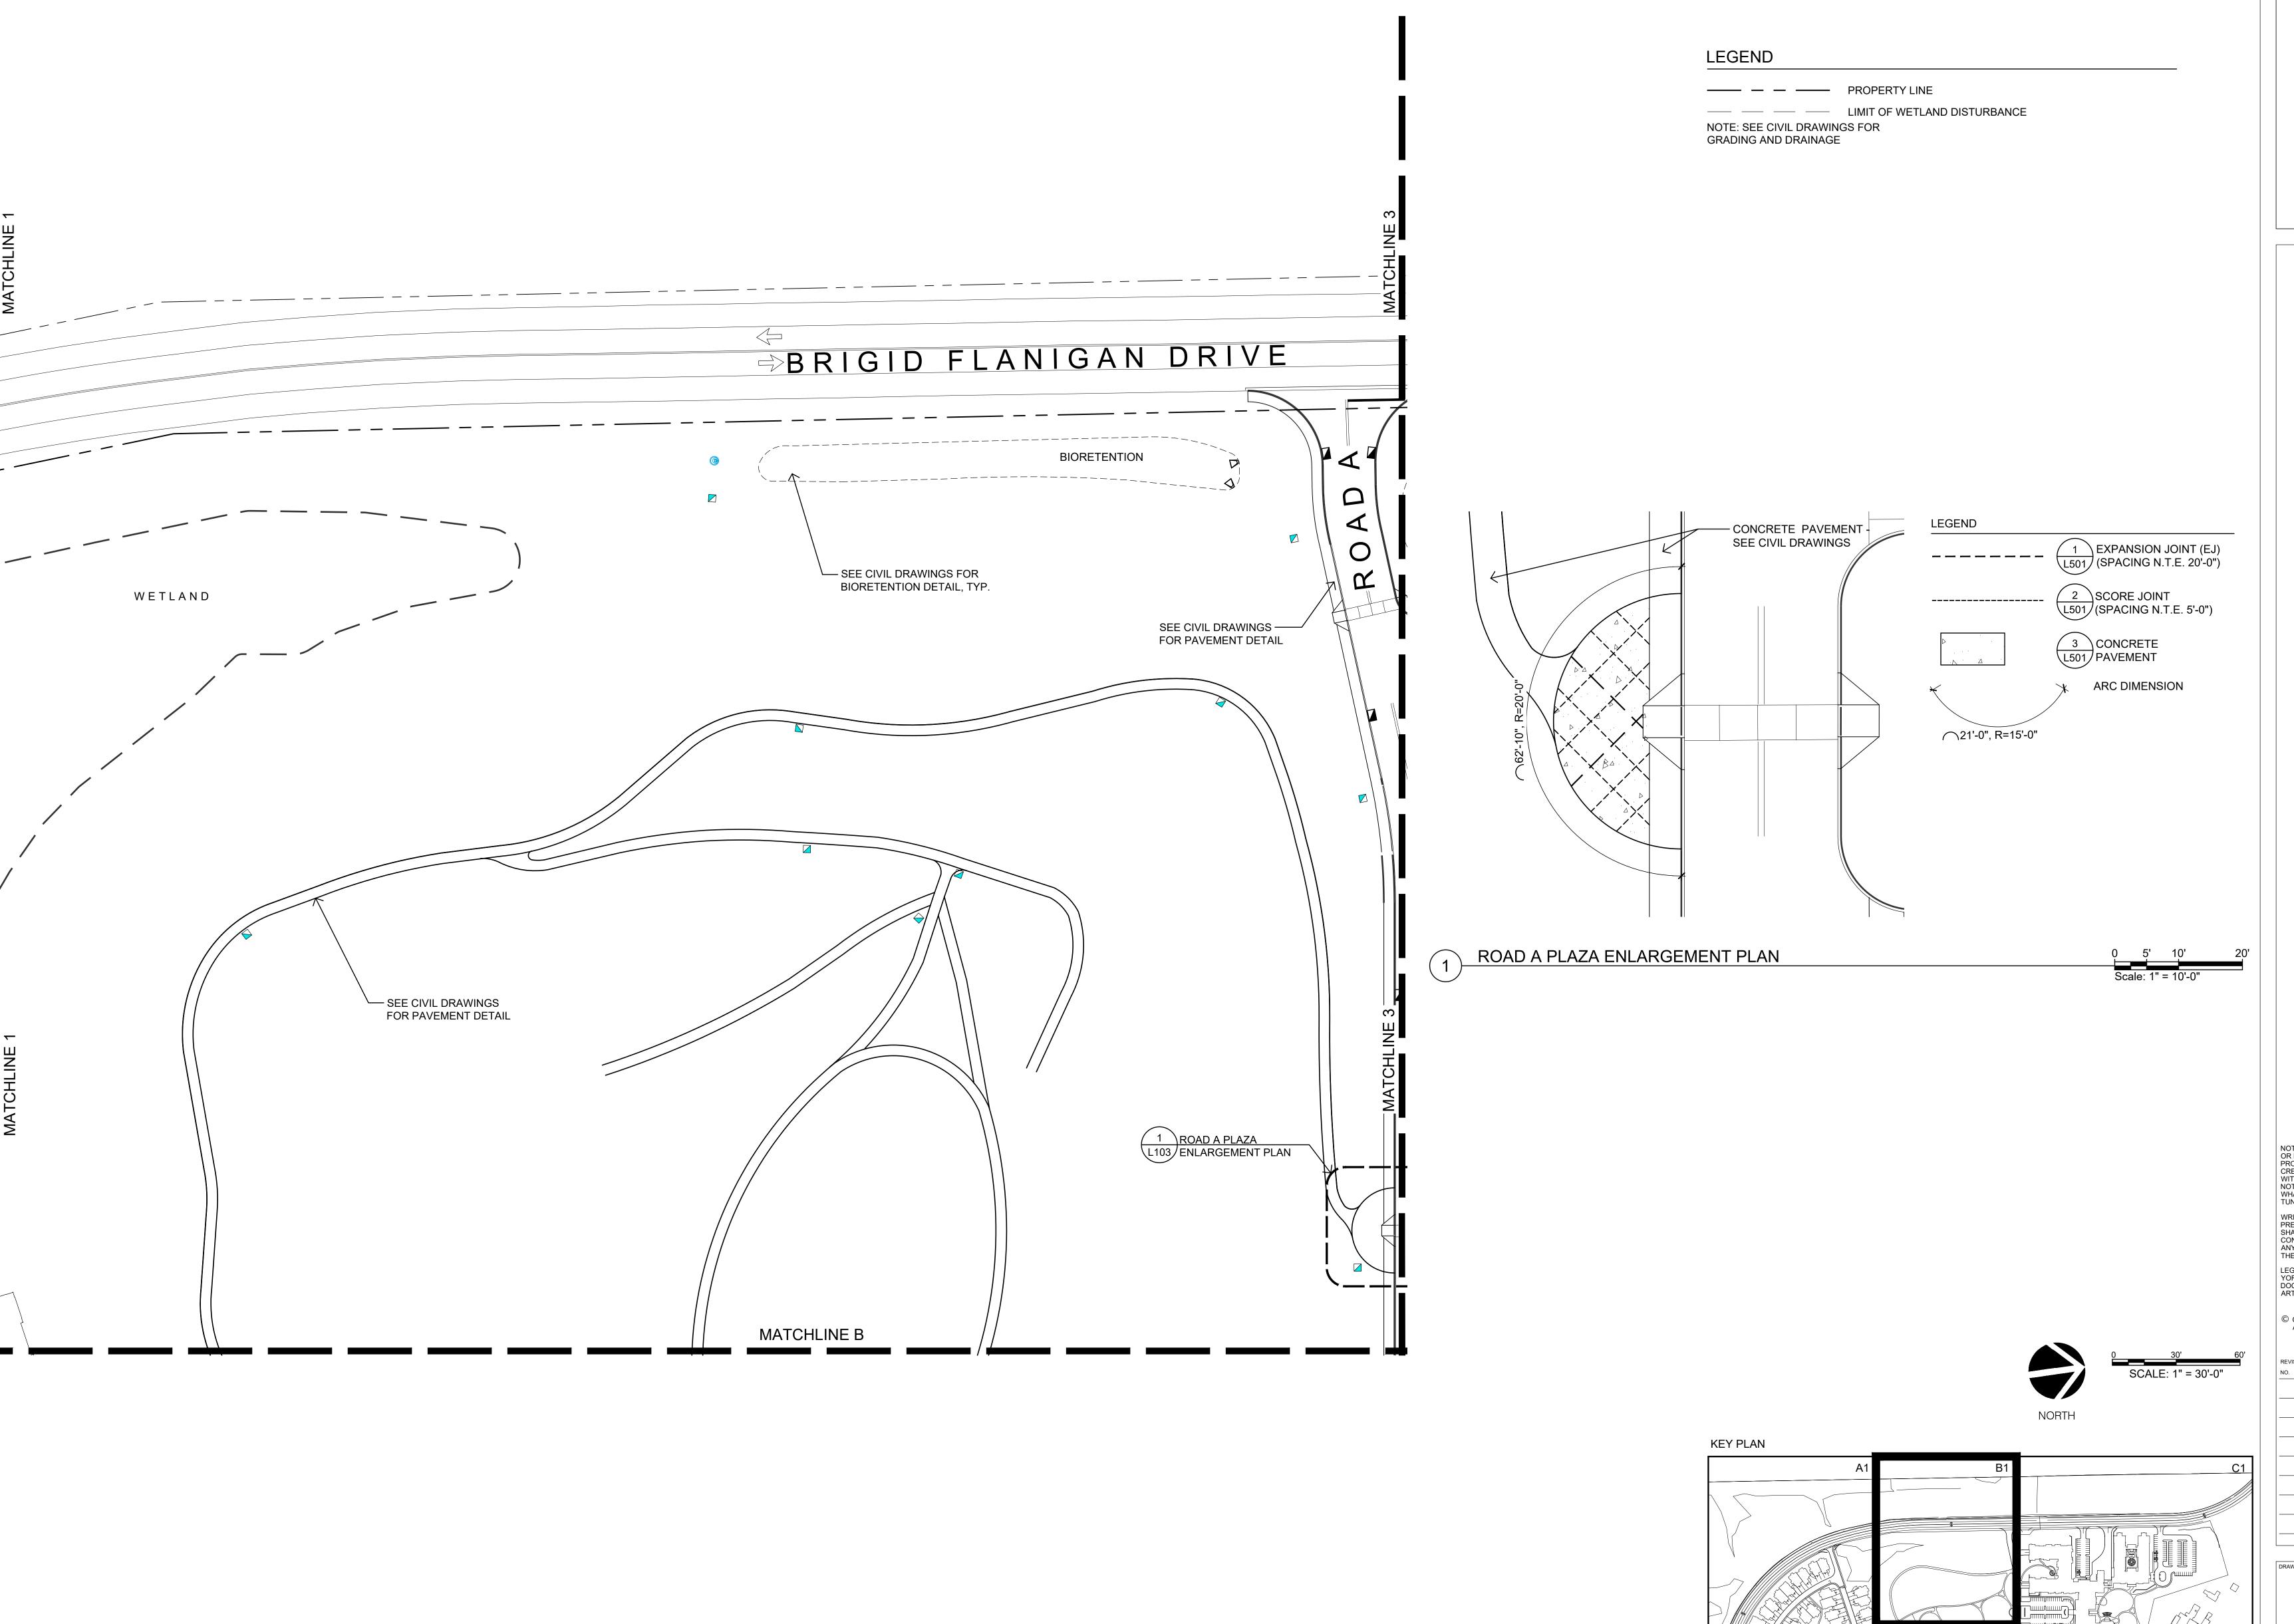

PLOTTED BY: DIVNEY TUNG SCHWALBE, LLP BREANA PARIAN 3/22/2021 4:31:56 PM M:\2015 PROJECTS\PL15006_SUNY PURCHASE 2015\MKW\CURRENT\L101-L106_LAYOUT AND MATERIALS.DWG



SENIOR LIVING
AT PURCHASE COLLEGE
Westchester County, New York

<u>SPONSOR</u>

Purchase College Learning Corporation 735 Anderson Hill Road Purchase, NY 10577-1402

PLANNER, CIVIL ENGINEER

DIVNEY • TUNG • SCHWALBE

Divney Tung Schwalbe, LLP One North Broadway White Plains, NY 10601

White Plains, NY 10601
P: 914.428.0010
F: 914.428.0017

400 Locust Street, Suite 820

<u>DEVELOPER</u> LCS DEVELOPMENT

ARCHITECT
HCM Design, Inc.

Des Moine, IA 50309

HCM Design, Inc. 750 East Pratt Street Baltimore, MD 21202

LANDSCAPE ARCHITECT
MKW and Associates, LLC
39 Park Avenue
Rutherford, NJ 07070

SURVEYOR

THE CHAZEN COMPANIES 21 Fox Street Poughkeepsie, NY 12601

WETLAND CONSULTANT
WILLIAM KENNY ASSOCIATES LLC
195 Tunxis Hill Cutoff South
Fairfield, CT 06825



NOTE: ALL SITE DESIGN CONCEPTS AND INFORMATION INDICATED OR REPRESENTED BY THIS DRAWING ARE OWNED BY AND ARE THE PROPERTY OF DIVNEY TUNG SCHWALBE, LLP. THIS DRAWING WAS CREATED AND DEVELOPED FOR USE ON, AND IN CONNECTION WITH, THE SPECIFIED PROJECT INDICATED HEREON AND SHALL NOT BE USED BY OR DISCLOSED TO ANY PERSON OR ENTITY WHATSOEVER WITHOUT THE WRITTEN PERMISSION OF DIVNEY TUNG SCHWALBE, LLP.

WRITTEN DIMENSIONS ON THIS DRAWING SHALL HAVE PRECEDENCE OVER SCALED MEASUREMENTS. CONTRACTOR SHALL VERIFY AND BE RESPONSIBLE FOR ALL DIMENSIONS AND CONDITIONS ON THE JOB AND THIS OFFICE MUST BE NOTIFIED OF ANY VARIATIONS FROM DIMENSIONS AND CONDITIONS SHOWN BY

THESE DRAWINGS.


LEGAL NOTICE: IT IS A VIOLATION OF ARTICLE 145 OF THE NEW YORK STATE EDUCATION LAW FOR ANY PERSON TO ALTER THIS DOCUMENT IN ANY WAY EXCEPT AS PROVIDED IN SECTION 7209 (2), ARTICLE 145, NEW YORK STATE EDUCATION LAW.

© Copyright Divney Tung Schwalbe, LLP 2019 All rights reserved.


REVIS	IONS	
NO.	DATE	ISSUE

OVERALL LAYOUT &
MATERIALS PLAN


3 OF 6

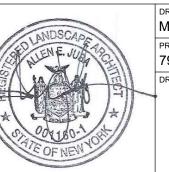



" = 300'

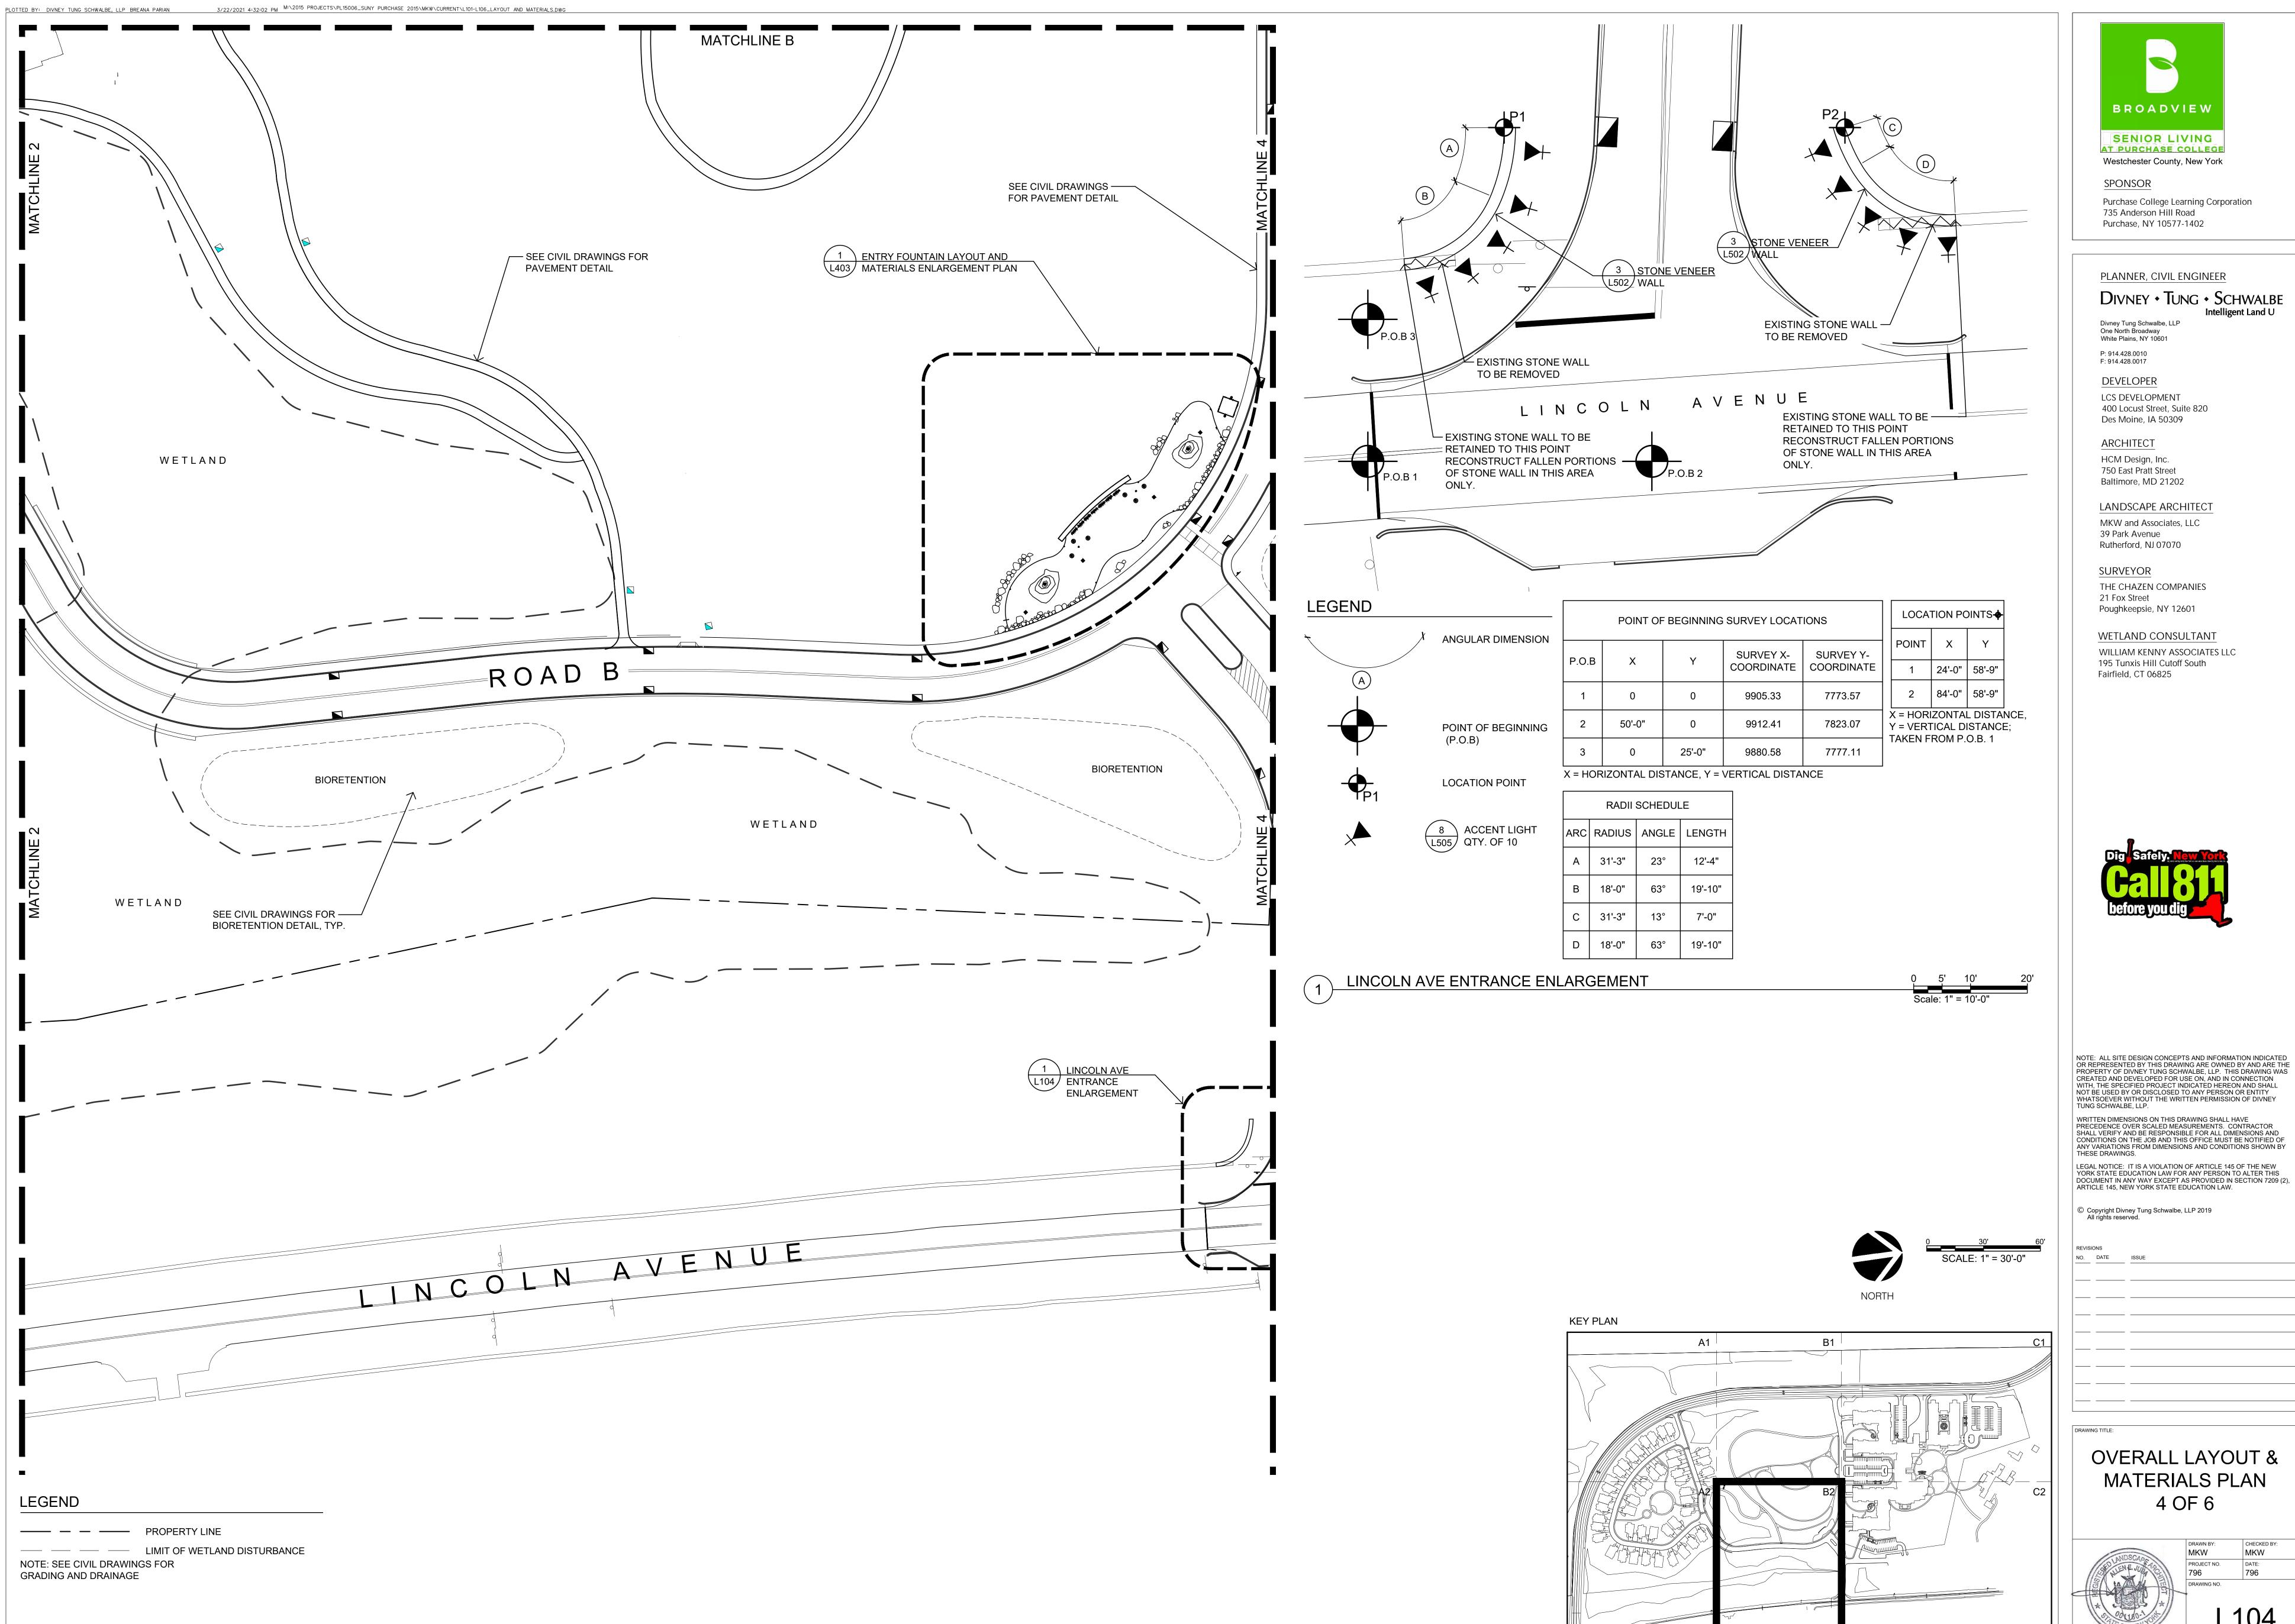



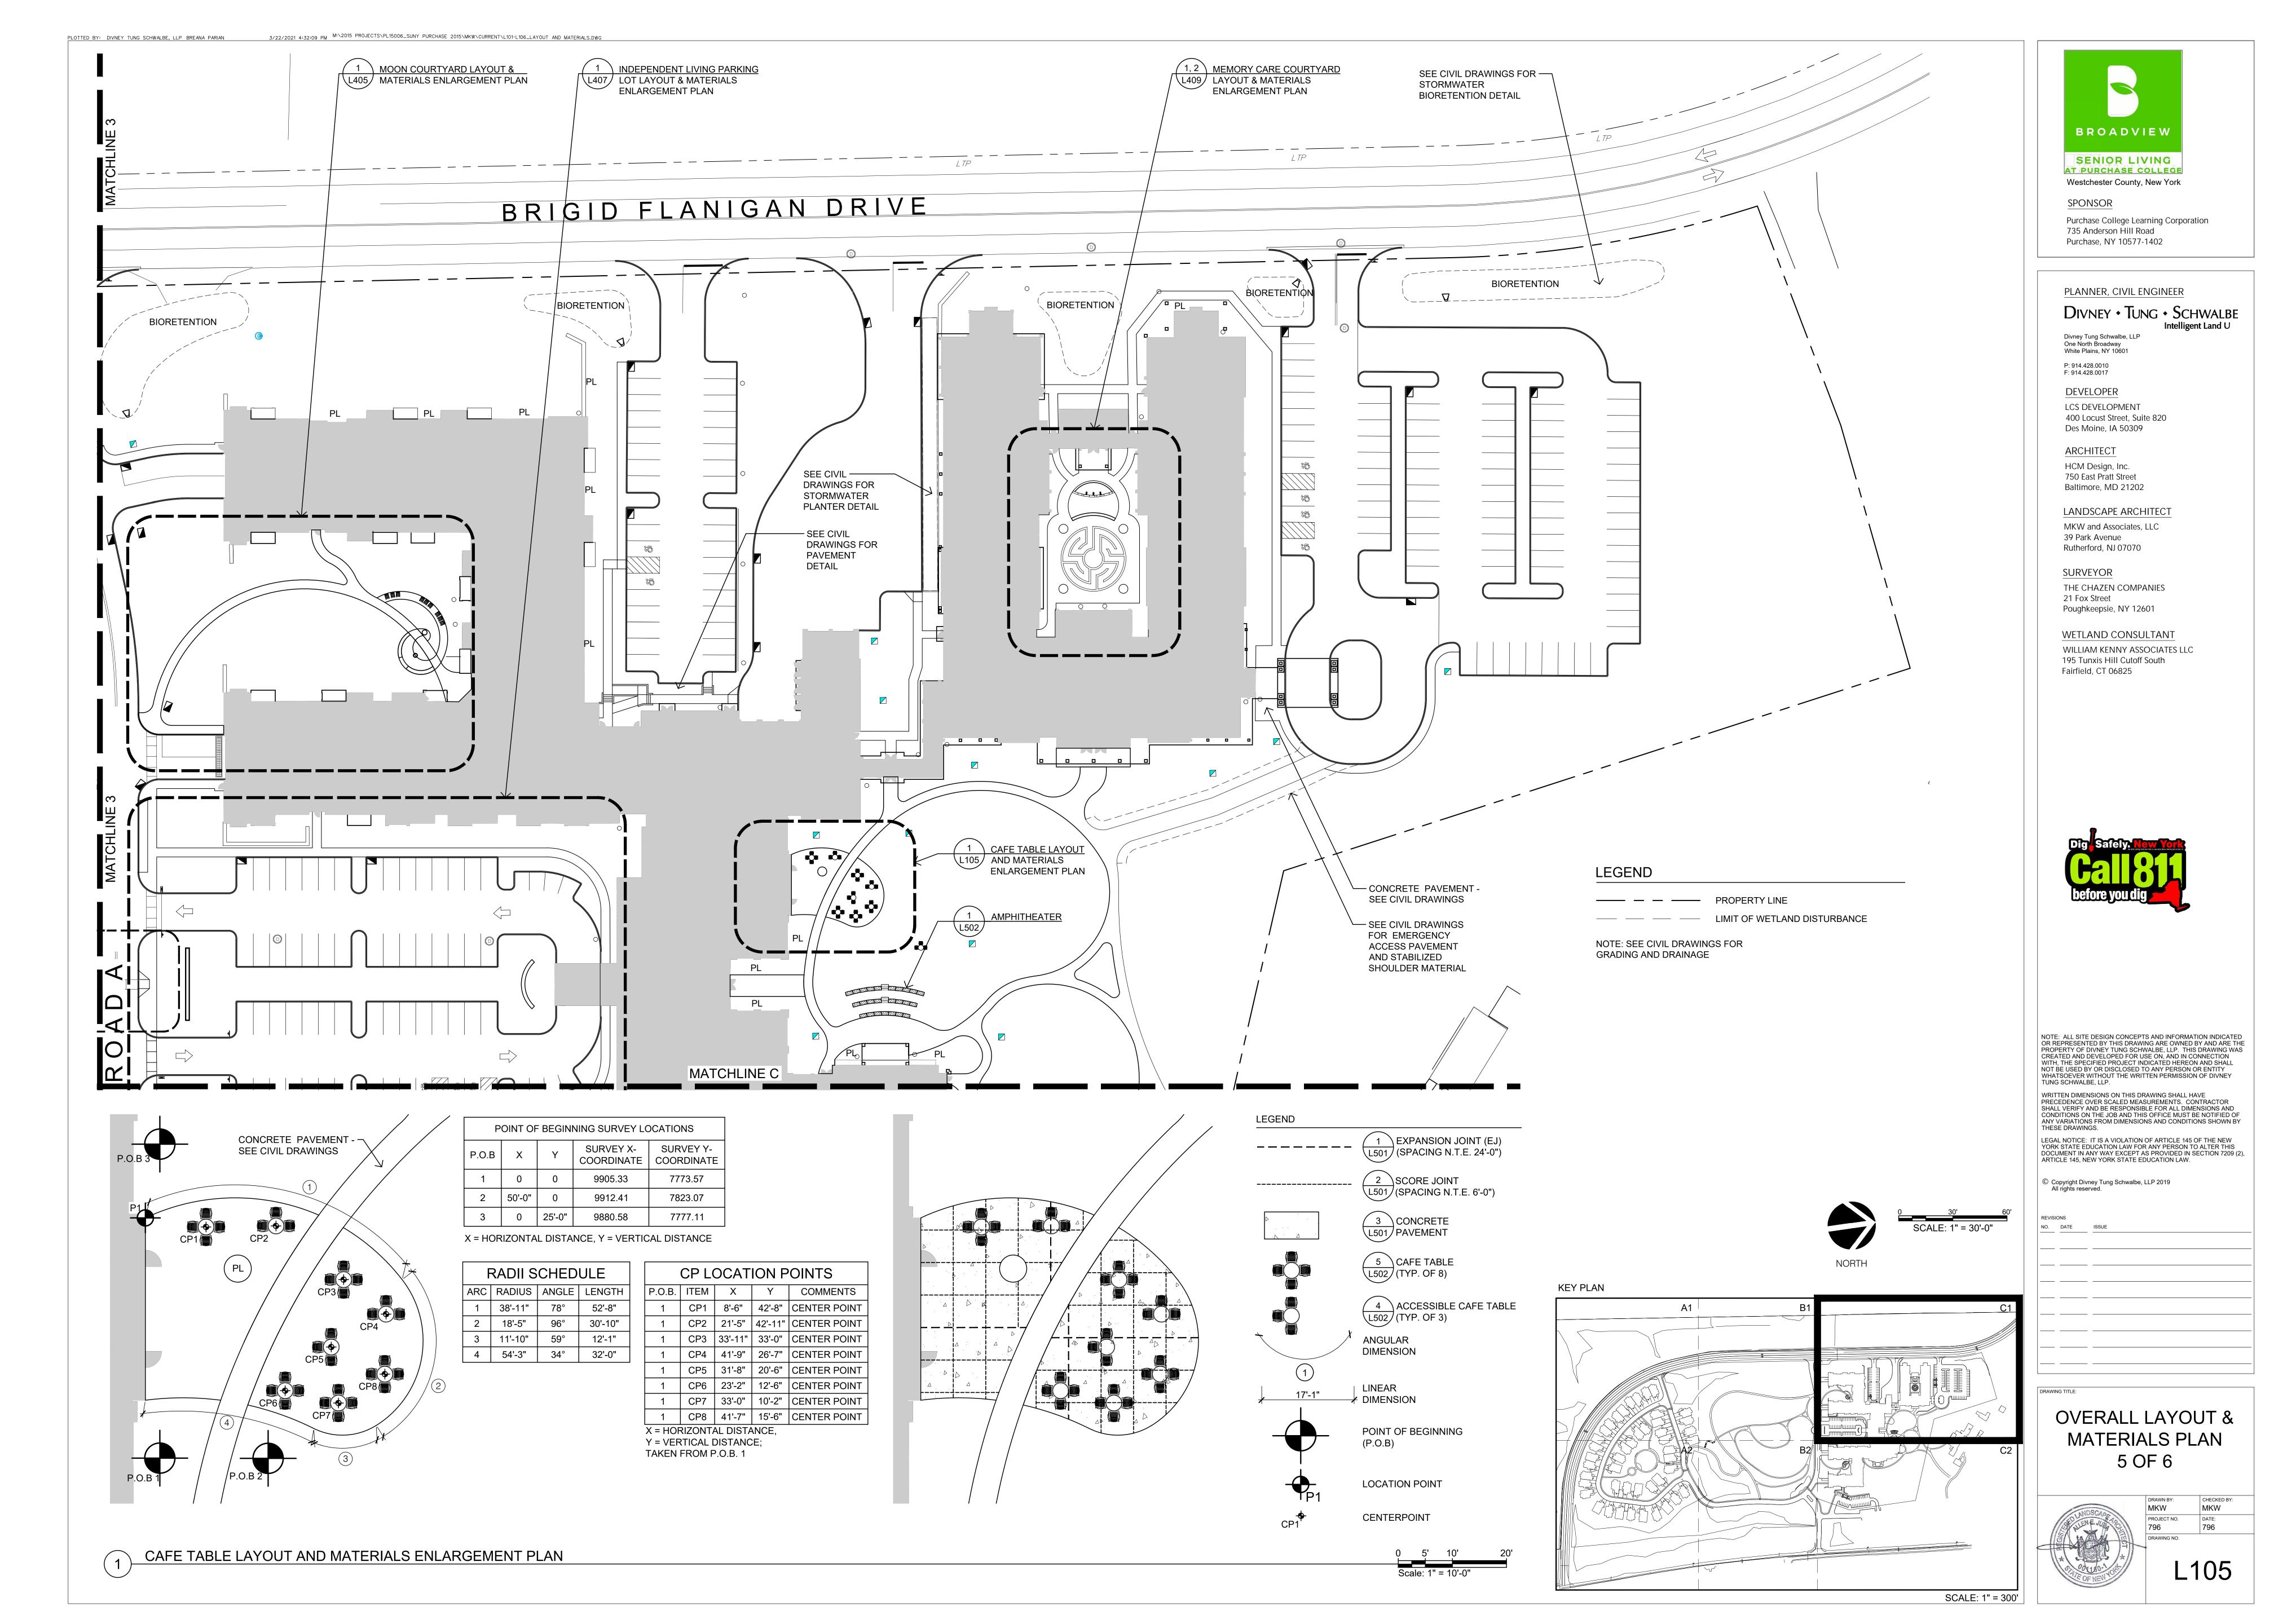

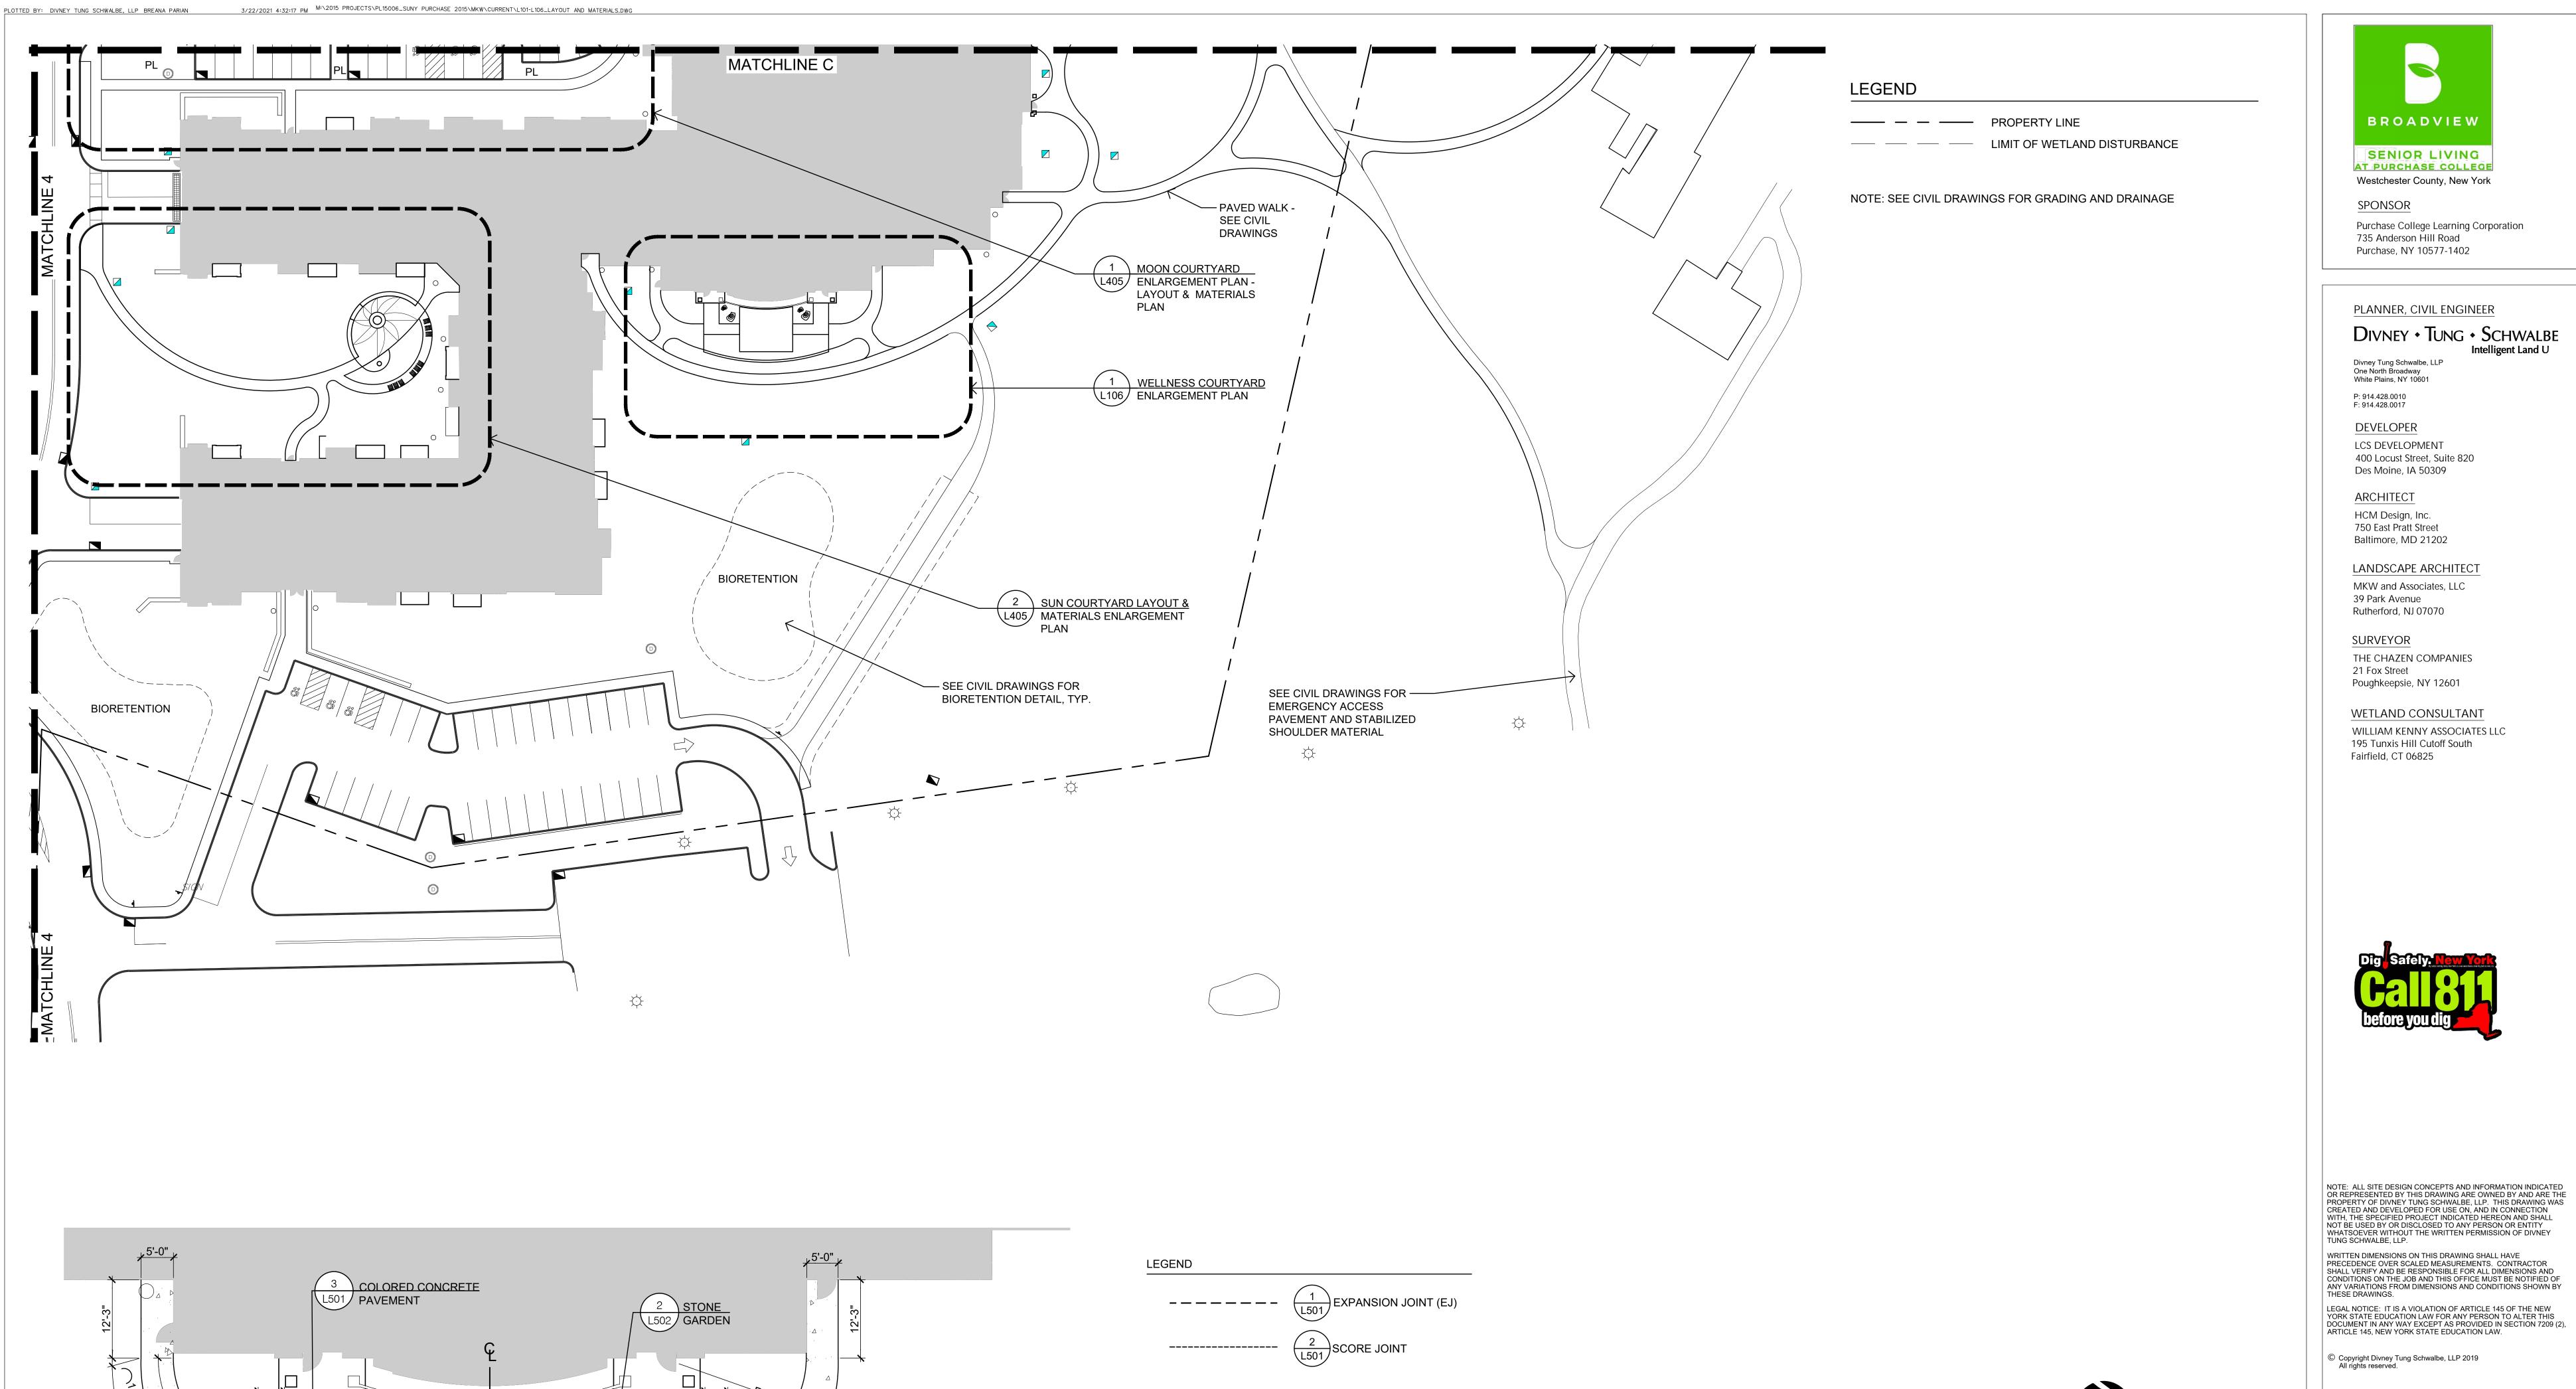

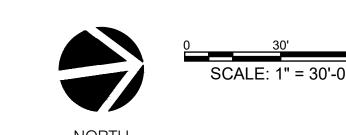

KEY PLAN

OVERALL LAYOUT & MATERIALS PLAN 6 OF 6

L106

BROADVIEW

SENIOR LIVING

SCALE: 1" = 300'

WELLNESS COURTYARD ENLARGEMENT PLAN

3 STONE L502 VENEER WALL

EQ. EQ.

R89'-2"

PAVED WALK - SEE —

CIVIL DRAWINGS

L/AWN

O CENTERLINE LINEAR DIMENSION 3 COLORED CONCRETE PAVEMENT -L501 COLOR: AUTUMN BEIGE

(L501) CONCRETE PAVEMENT


WOOD DECKING

 
STONE GARDEN

LOCATION POINT

PLANTED AREA

 
NOTE: SEE CIVIL DRAWINGS FOR GRADING AND DRAINAGE

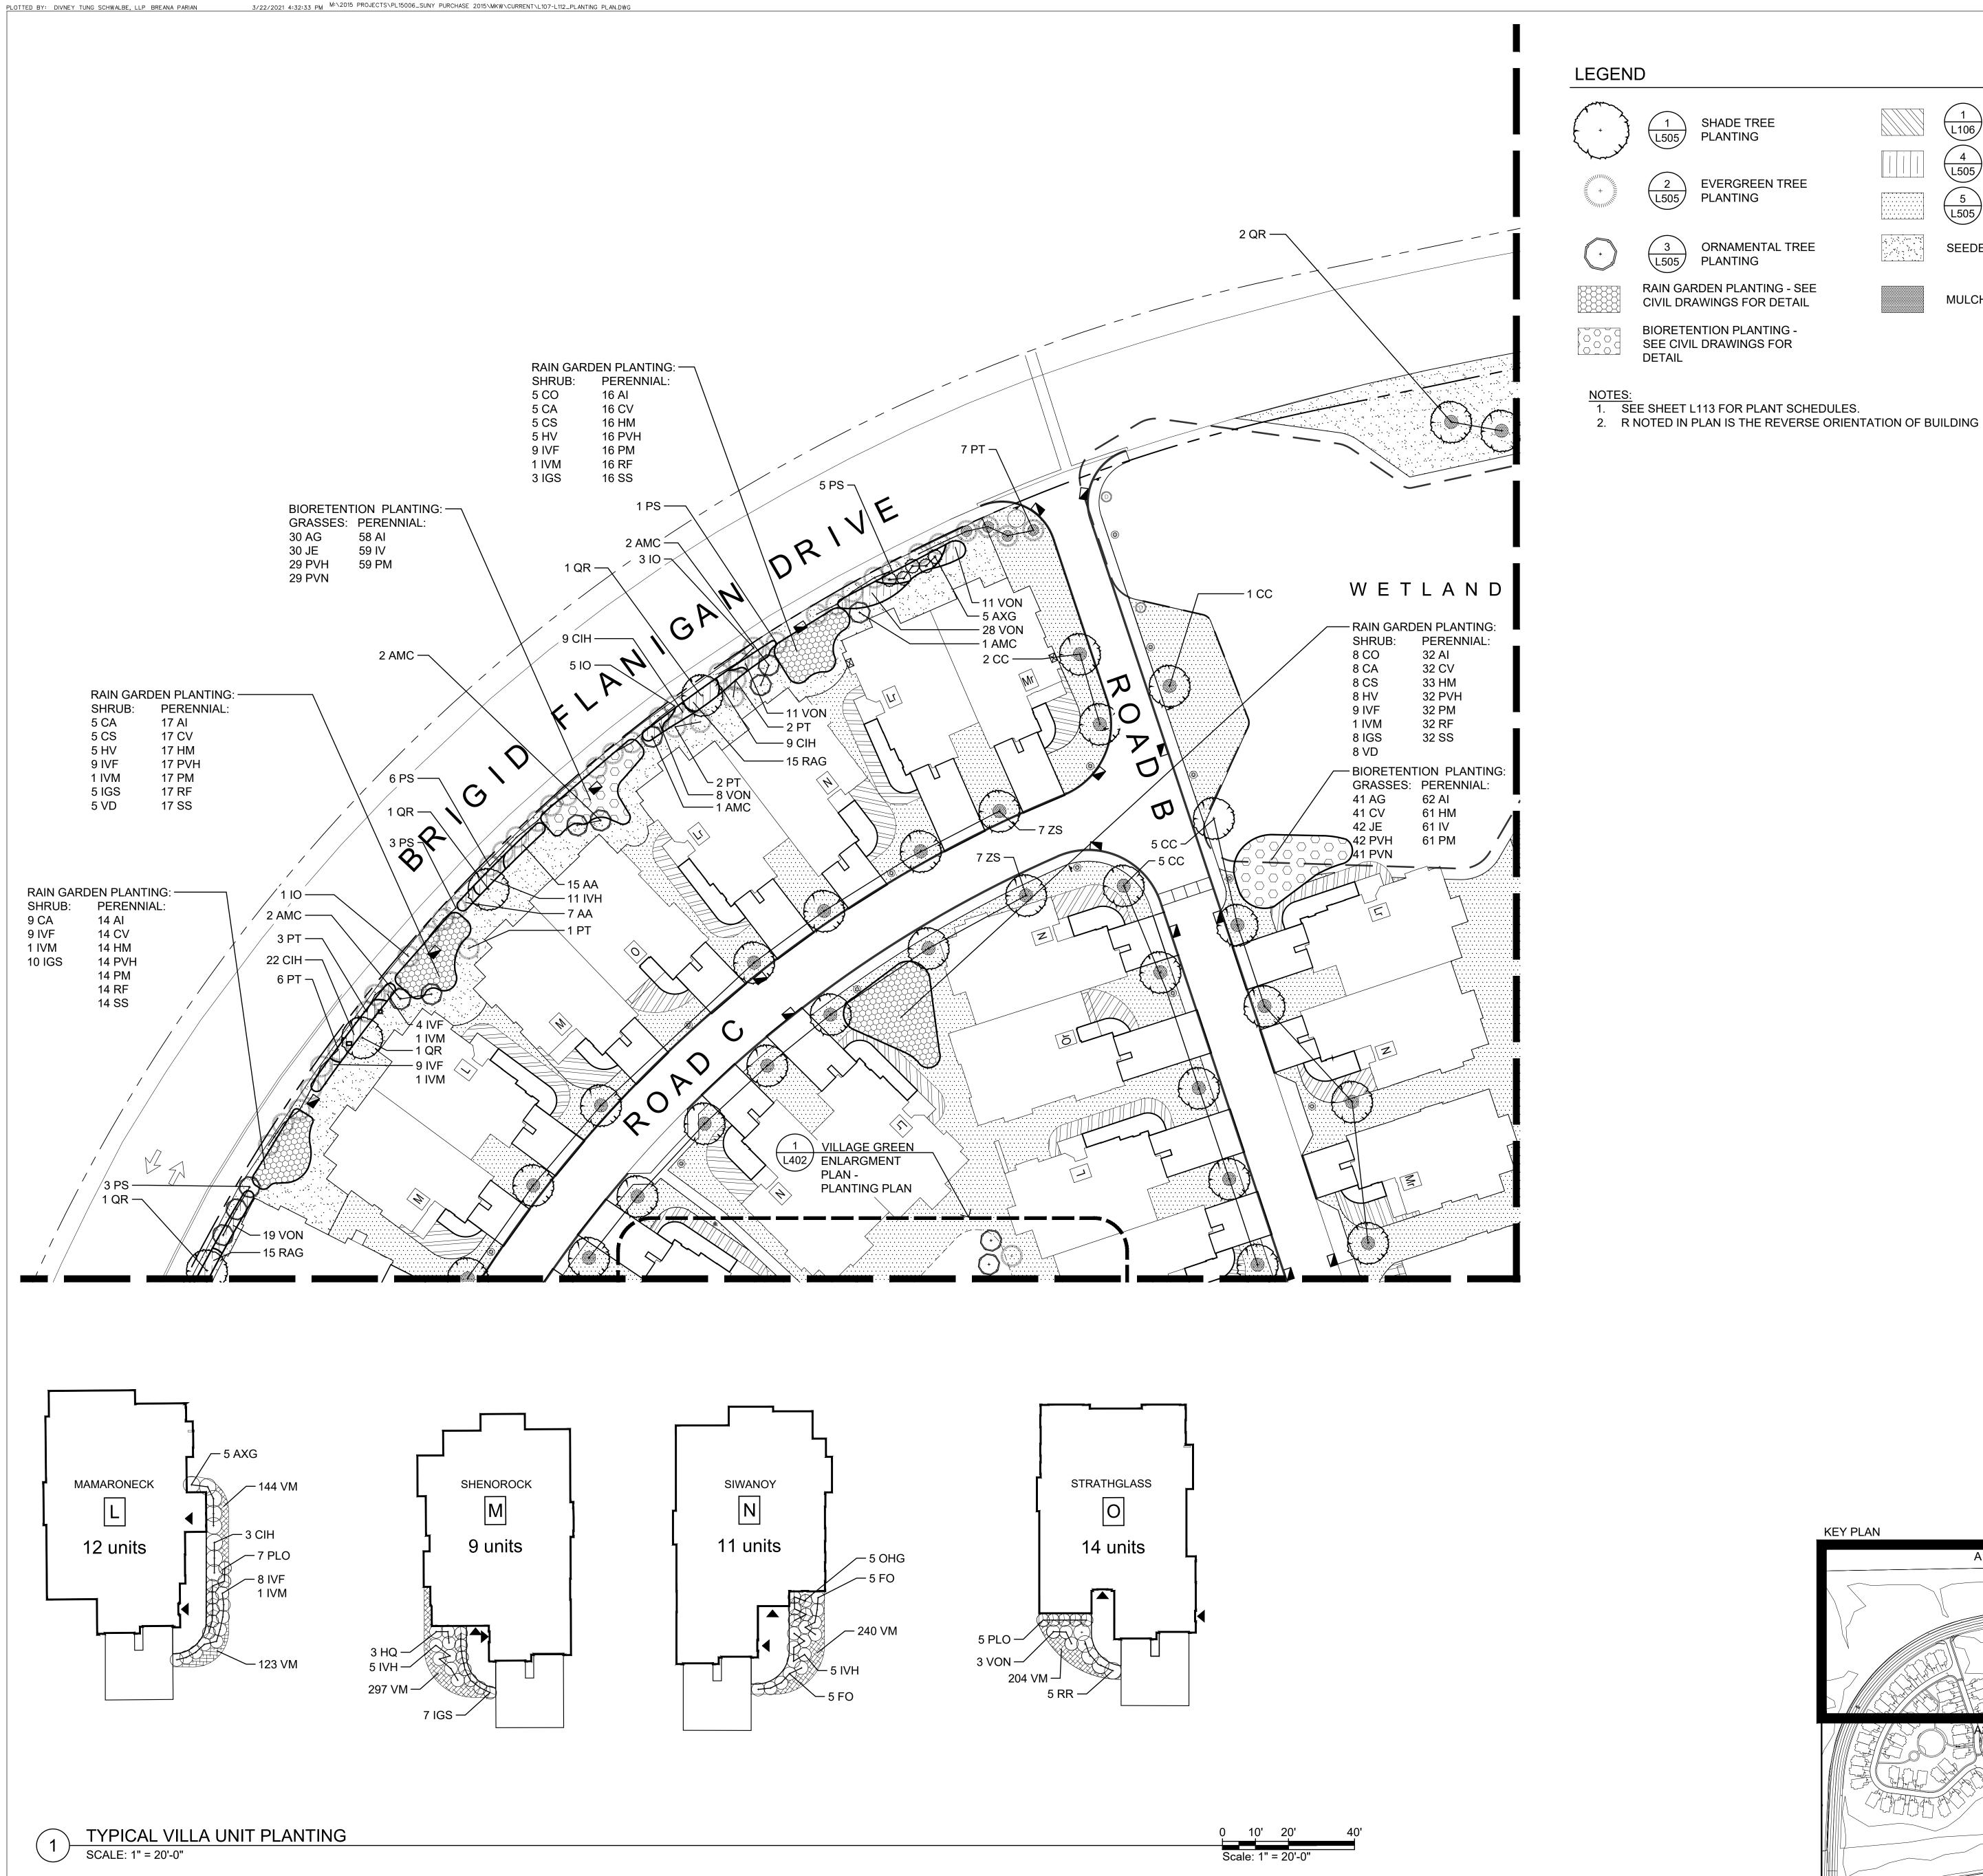











SODDED LAWN



SEEDED LAWN



EVERGREEN TREE PLANTING



ORNAMENTAL TREE PLANTING






MULCH - 2" DEPTH

KEY PLAN

BIORETENTION PLANTING -SEE CIVIL DRAWINGS FOR DETAIL

1. SEE SHEET L113 FOR PLANT SCHEDULES.

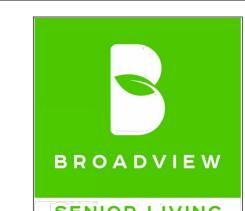

SENIOR LIVING AT PURCHASE COLLEGE Westchester County, New York

SPONSOR

Purchase College Learning Corporation 735 Anderson Hill Road Purchase, NY 10577-1402

PLANNER, CIVIL ENGINEER

DIVNEY • TUNG • SCHWALBE

Divney Tung Schwalbe, LLP One North Broadway White Plains, NY 10601

P: 914.428.0010 F: 914.428.0017

DEVELOPER

LCS DEVELOPMENT 400 Locust Street, Suite 820 Des Moine, IA 50309

<u>ARCHITECT</u> HCM Design, Inc.

750 East Pratt Street Baltimore, MD 21202

LANDSCAPE ARCHITECT MKW and Associates, LLC 39 Park Avenue Rutherford, NJ 07070

SURVEYOR

THE CHAZEN COMPANIES 21 Fox Street Poughkeepsie, NY 12601

WETLAND CONSULTANT WILLIAM KENNY ASSOCIATES LLC 195 Tunxis Hill Cutoff South Fairfield, CT 06825



NOTE: ALL SITE DESIGN CONCEPTS AND INFORMATION INDICATED OR REPRESENTED BY THIS DRAWING ARE OWNED BY AND ARE THE PROPERTY OF DIVNEY TUNG SCHWALBE, LLP. THIS DRAWING WAS CREATED AND DEVELOPED FOR USE ON, AND IN CONNECTION WITH, THE SPECIFIED PROJECT INDICATED HEREON AND SHALL NOT BE USED BY OR DISCLOSED TO ANY PERSON OR ENTITY WHATSOEVER WITHOUT THE WRITTEN PERMISSION OF DIVNEY TUNG SCHWALBE, LLP.

WRITTEN DIMENSIONS ON THIS DRAWING SHALL HAVE PRECEDENCE OVER SCALED MEASUREMENTS. CONTRACTOR SHALL VERIFY AND BE RESPONSIBLE FOR ALL DIMENSIONS AND CONDITIONS ON THE JOB AND THIS OFFICE MUST BE NOTIFIED OF ANY VARIATIONS FROM DIMENSIONS AND CONDITIONS SHOWN BY

LEGAL NOTICE: IT IS A VIOLATION OF ARTICLE 145 OF THE NEW YORK STATE EDUCATION LAW FOR ANY PERSON TO ALTER THIS DOCUMENT IN ANY WAY EXCEPT AS PROVIDED IN SECTION 7209 (2),

ARTICLE 145, NEW YORK STATE EDUCATION LAW.


© Copyright Divney Tung Schwalbe, LLP 2019 All rights reserved.

SCALE: 1" = 30'-0"

SCALE: 1" = 300'

PLANTING PLAN 1 OF 6



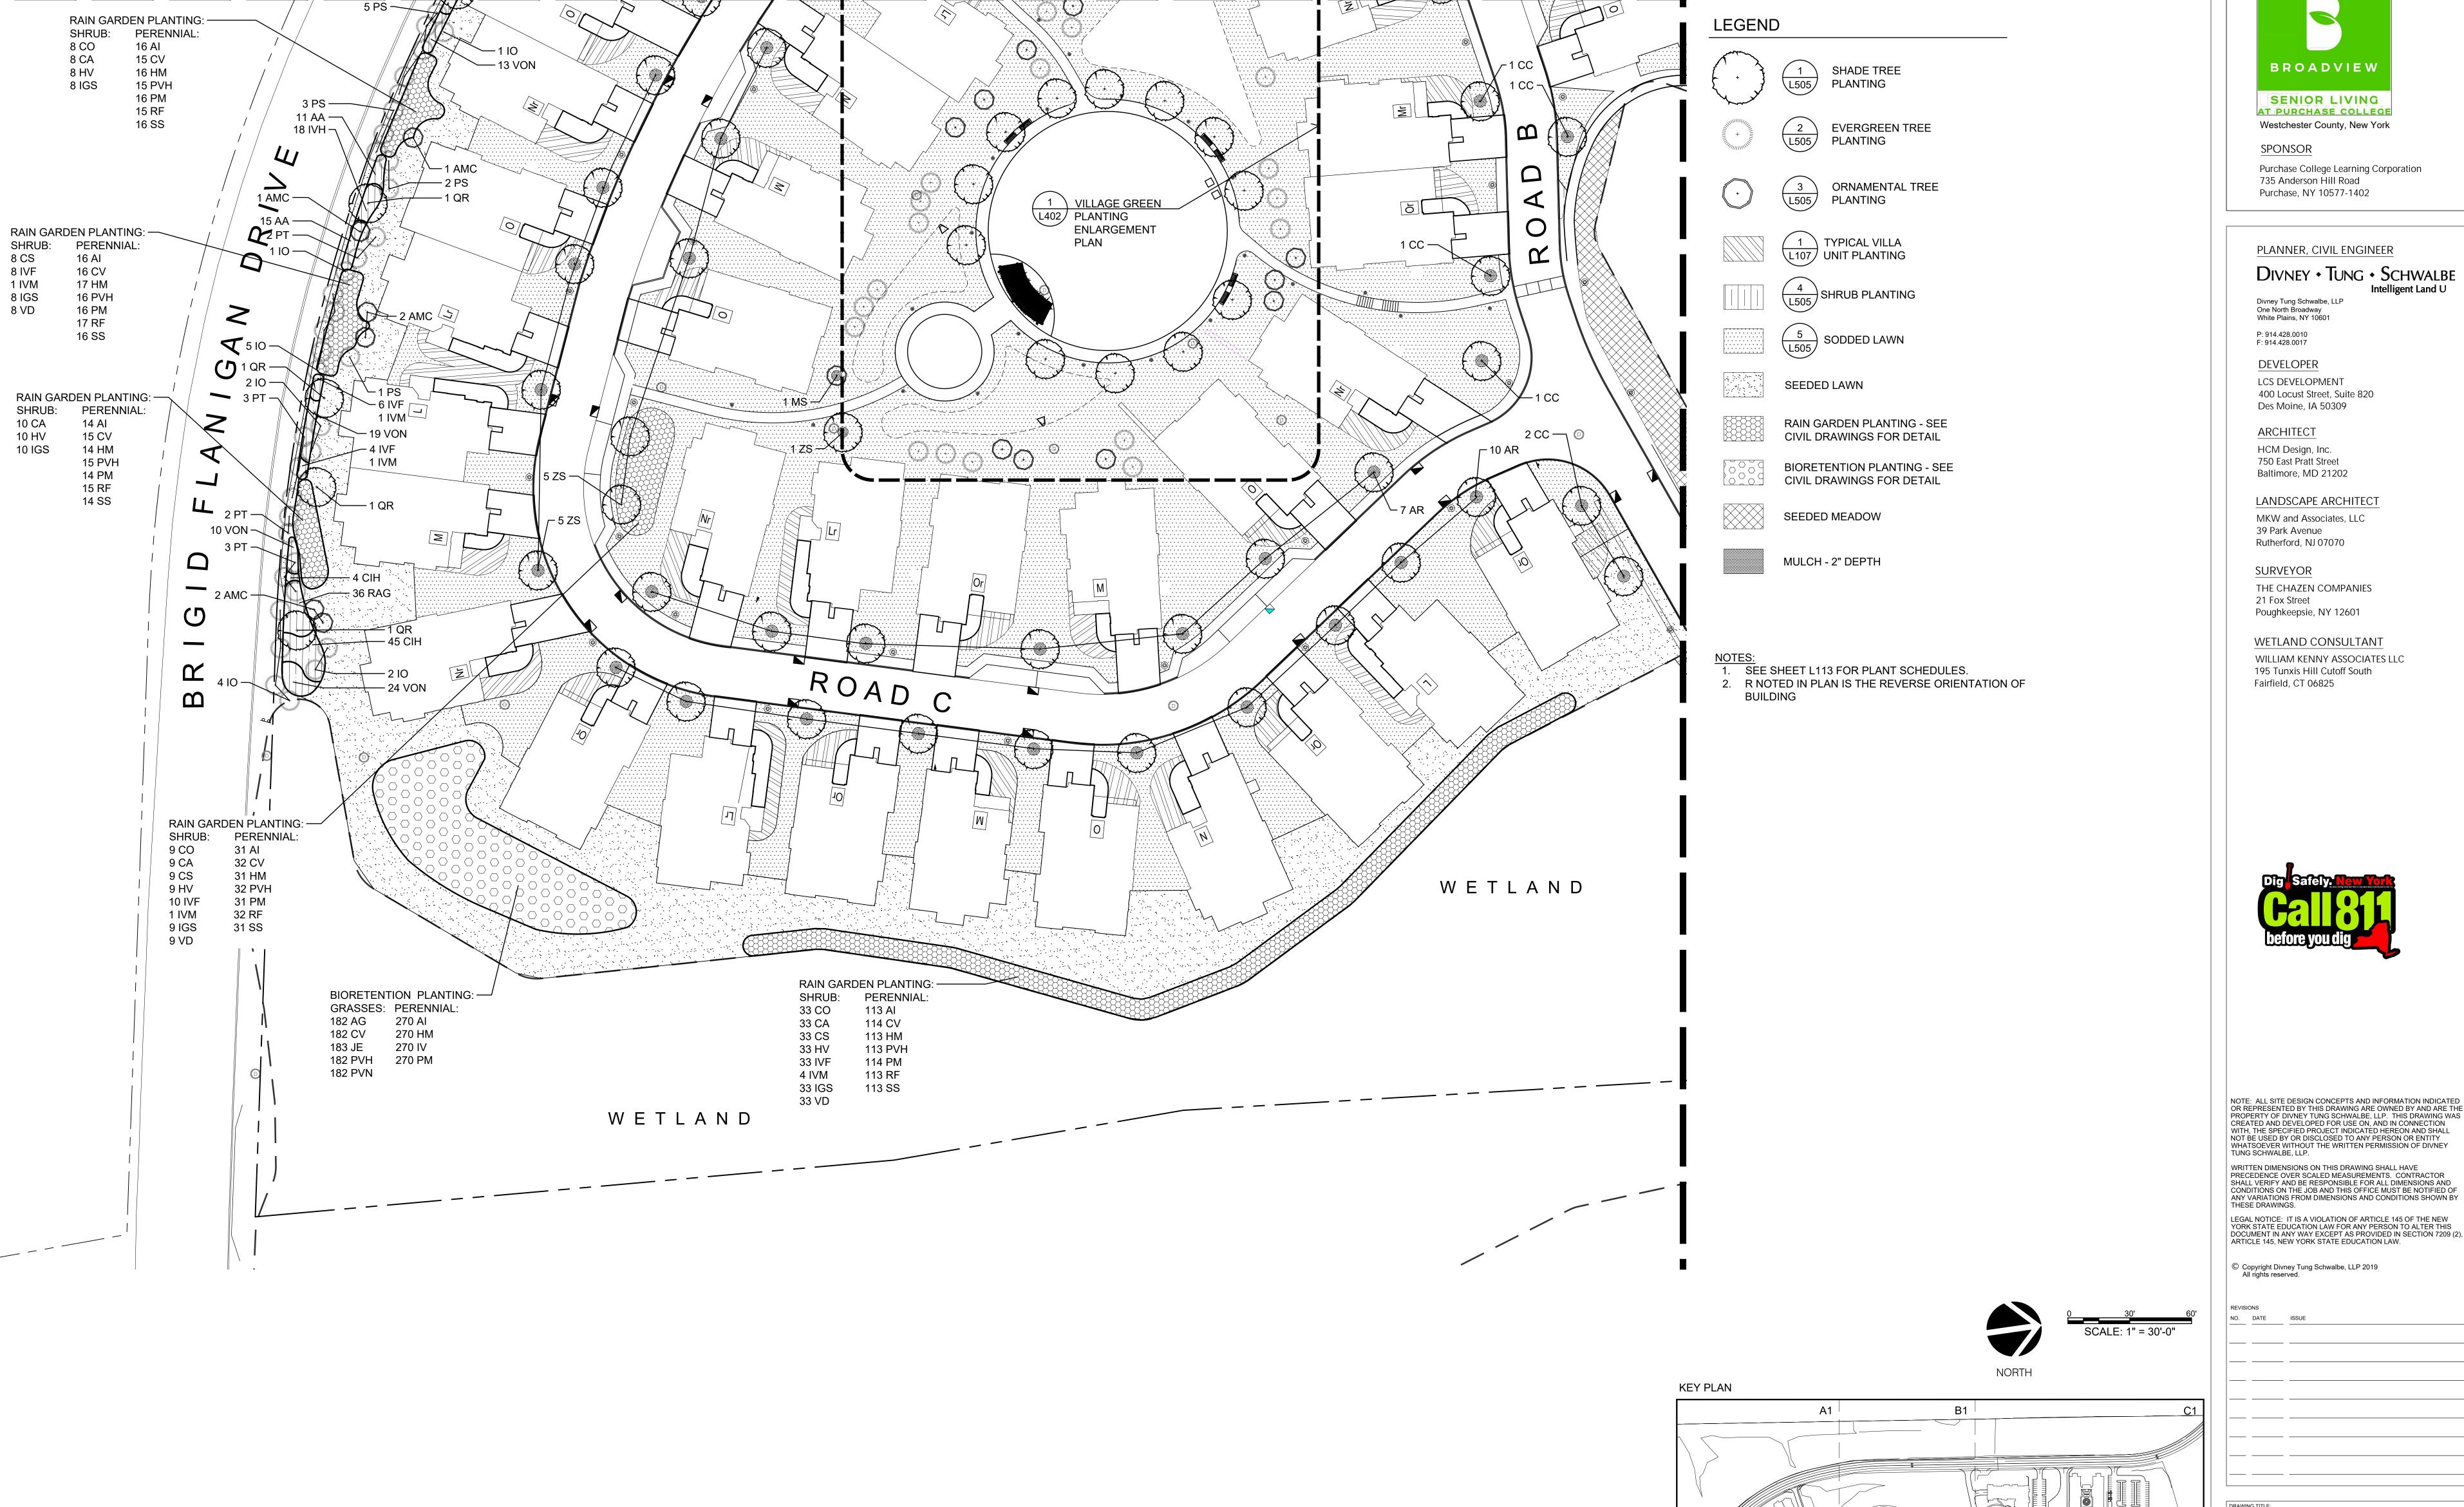

PLOTTED BY: DIVNEY TUNG SCHWALBE, LLP BREANA PARIAN 3/22/2021 4:32:43 PM M:\2015 PROJECTS\PL15006_SUNY PURCHASE 2015\MKW\CURRENT\L107-L112_PLANTING PLAN.DWG



AT PURCHASE COLLEGE Westchester County, New York

Purchase College Learning Corporation 735 Anderson Hill Road Purchase, NY 10577-1402

PLANNER, CIVIL ENGINEER

DIVNEY • TUNG • SCHWALBE

LCS DEVELOPMENT

HCM Design, Inc. 750 East Pratt Street

Baltimore, MD 21202

MKW and Associates, LLC

THE CHAZEN COMPANIES

Poughkeepsie, NY 12601

WETLAND CONSULTANT WILLIAM KENNY ASSOCIATES LLC 195 Tunxis Hill Cutoff South



NOTE: ALL SITE DESIGN CONCEPTS AND INFORMATION INDICATED OR REPRESENTED BY THIS DRAWING ARE OWNED BY AND ARE THE PROPERTY OF DIVNEY TUNG SCHWALBE, LLP. THIS DRAWING WAS CREATED AND DEVELOPED FOR USE ON, AND IN CONNECTION WITH, THE SPECIFIED PROJECT INDICATED HEREON AND SHALL NOT BE USED BY OR DISCLOSED TO ANY PERSON OR ENTITY WHATSOEVER WITHOUT THE WRITTEN PERMISSION OF DIVNEY TUNG SCHWALBE, LLP.

WRITTEN DIMENSIONS ON THIS DRAWING SHALL HAVE PRECEDENCE OVER SCALED MEASUREMENTS. CONTRACTOR SHALL VERIFY AND BE RESPONSIBLE FOR ALL DIMENSIONS AND CONDITIONS ON THE JOB AND THIS OFFICE MUST BE NOTIFIED OF ANY VARIATIONS FROM DIMENSIONS AND CONDITIONS SHOWN BY

ARTICLE 145, NEW YORK STATE EDUCATION LAW.


REVISI	ONS	
NO.	DATE	ISSUE


SCALE: 1" = 300'

PLANTING PLAN

 
2 OF 6



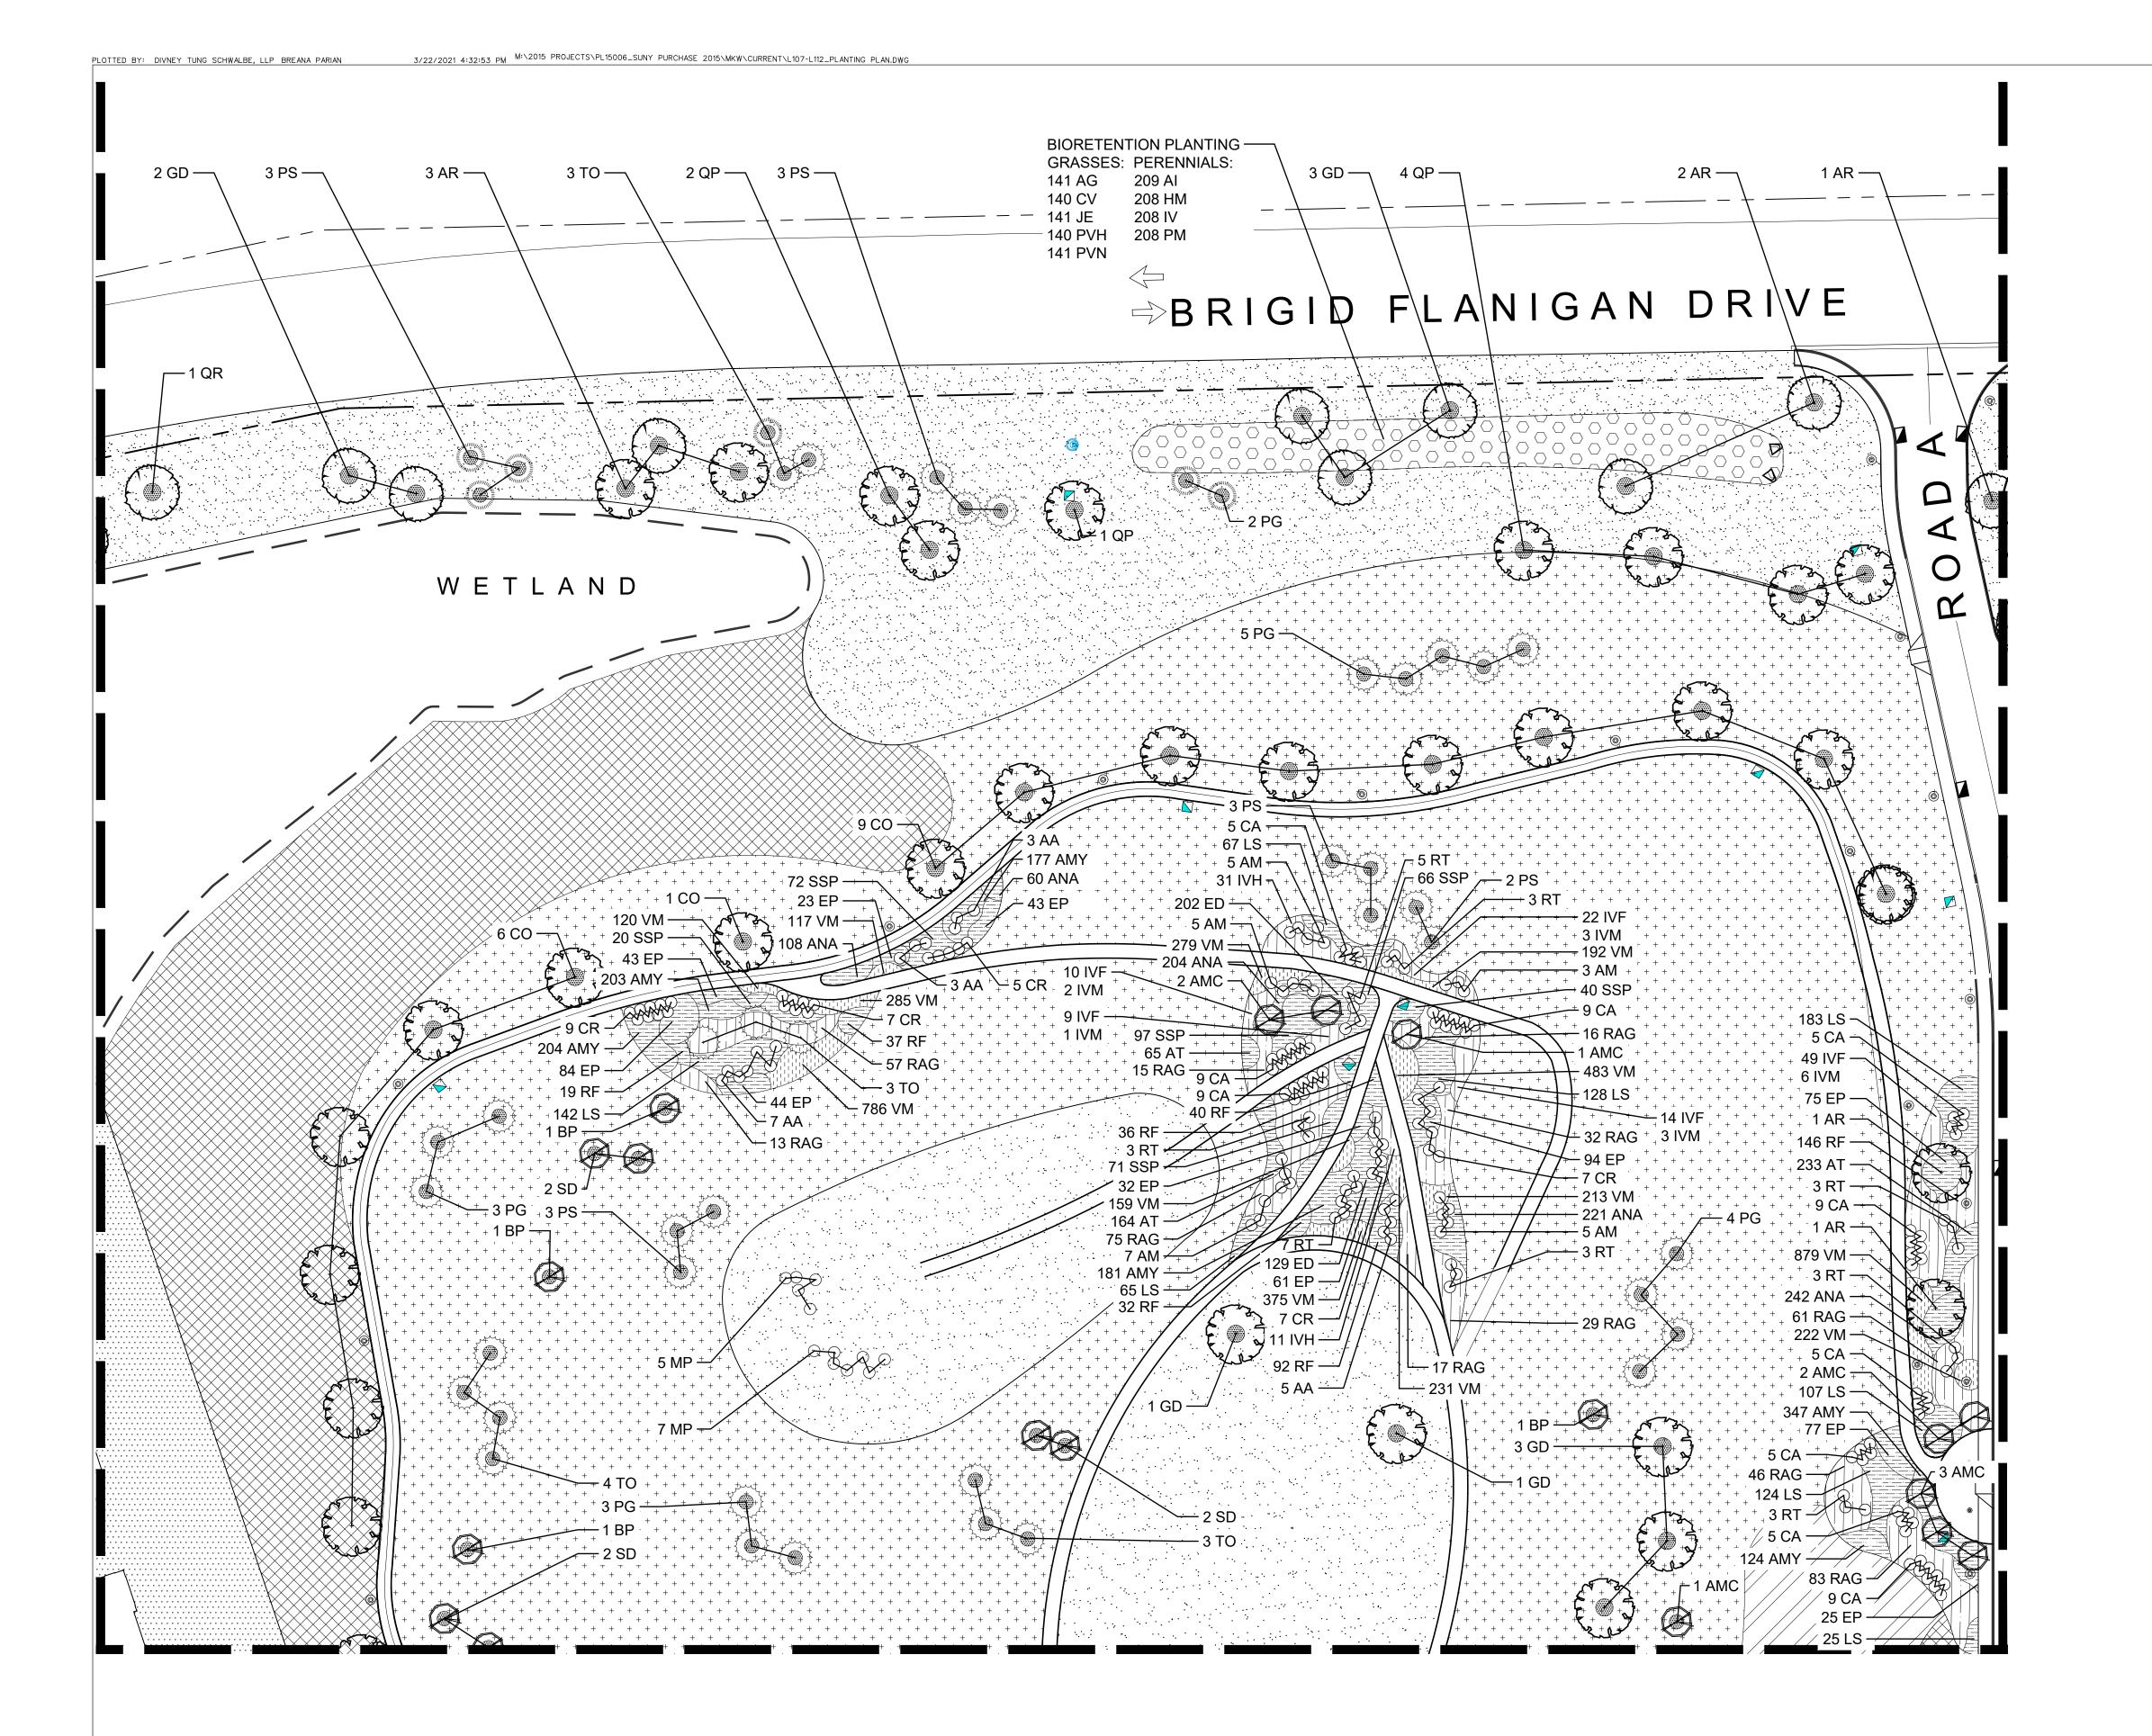





L506 LANDFILL

 

 
BIORETENTION PLANTING - SEE CIVIL DRAWINGS FOR DETAIL



SEEDED BUTTERFLY MEADOW

 

SEEDED MEADOW

 


SEEDED LAWN




2 EVERGREEN TREE PLANTING - LANDFILL

 1 SHADE TREE PLANTING -




 SEEDED LAWN (UNMOWN) 5 GROUNDCOVER PLANTING -




L506 LANDFILL

 5 PERENNIALS, GRASSES - LANDFILL



MULCH - 2" DEPTH

 NOTE: SEE SHEET L113 FOR PLANT SCHEDULES.



BROADVIEW

SENIOR LIVING AT PURCHASE COLLEGE

Westchester County, New York

SPONSOR

PLANNER, CIVIL ENGINEER

Purchase College Learning Corporation 735 Anderson Hill Road

DIVNEY • TUNG • SCHWALBE

Divney Tung Schwalbe, LLP One North Broadway White Plains, NY 10601

P: 914.428.0010 F: 914.428.0017

DEVELOPER LCS DEVELOPMENT

400 Locust Street, Suite 820 Des Moine, IA 50309 **ARCHITECT**

HCM Design, Inc. 750 East Pratt Street

Baltimore, MD 21202

LANDSCAPE ARCHITECT MKW and Associates, LLC 39 Park Avenue

SURVEYOR THE CHAZEN COMPANIES

Rutherford, NJ 07070

21 Fox Street Poughkeepsie, NY 12601

WETLAND CONSULTANT WILLIAM KENNY ASSOCIATES LLC 195 Tunxis Hill Cutoff South Fairfield, CT 06825



NOTE: ALL SITE DESIGN CONCEPTS AND INFORMATION INDICATED OR REPRESENTED BY THIS DRAWING ARE OWNED BY AND ARE THE PROPERTY OF DIVNEY TUNG SCHWALBE, LLP. THIS DRAWING WAS CREATED AND DEVELOPED FOR USE ON, AND IN CONNECTION WITH, THE SPECIFIED PROJECT INDICATED HEREON AND SHALL NOT BE USED BY OR DISCLOSED TO ANY PERSON OR ENTITY WHATSOEVER WITHOUT THE WRITTEN PERMISSION OF DIVNEY TUNG SCHWALBE, LLP.

WRITTEN DIMENSIONS ON THIS DRAWING SHALL HAVE PRECEDENCE OVER SCALED MEASUREMENTS. CONTRACTOR SHALL VERIFY AND BE RESPONSIBLE FOR ALL DIMENSIONS AND CONDITIONS ON THE JOB AND THIS OFFICE MUST BE NOTIFIED OF ANY VARIATIONS FROM DIMENSIONS AND CONDITIONS SHOWN BY

LEGAL NOTICE: IT IS A VIOLATION OF ARTICLE 145 OF THE NEW YORK STATE EDUCATION LAW FOR ANY PERSON TO ALTER THIS DOCUMENT IN ANY WAY EXCEPT AS PROVIDED IN SECTION 7209 (2),

© Copyright Divney Tung Schwalbe, LLP 2019 All rights reserved.

ARTICLE 145, NEW YORK STATE EDUCATION LAW.

REVIS	IONS		
NO.	DATE	ISSUE	
	. <u> </u>		

SCALE: 1" = 300'


PLANTING PLAN 3 OF 6




L109

 
SCALE: 1" = 30'-0"

KEY PLAN

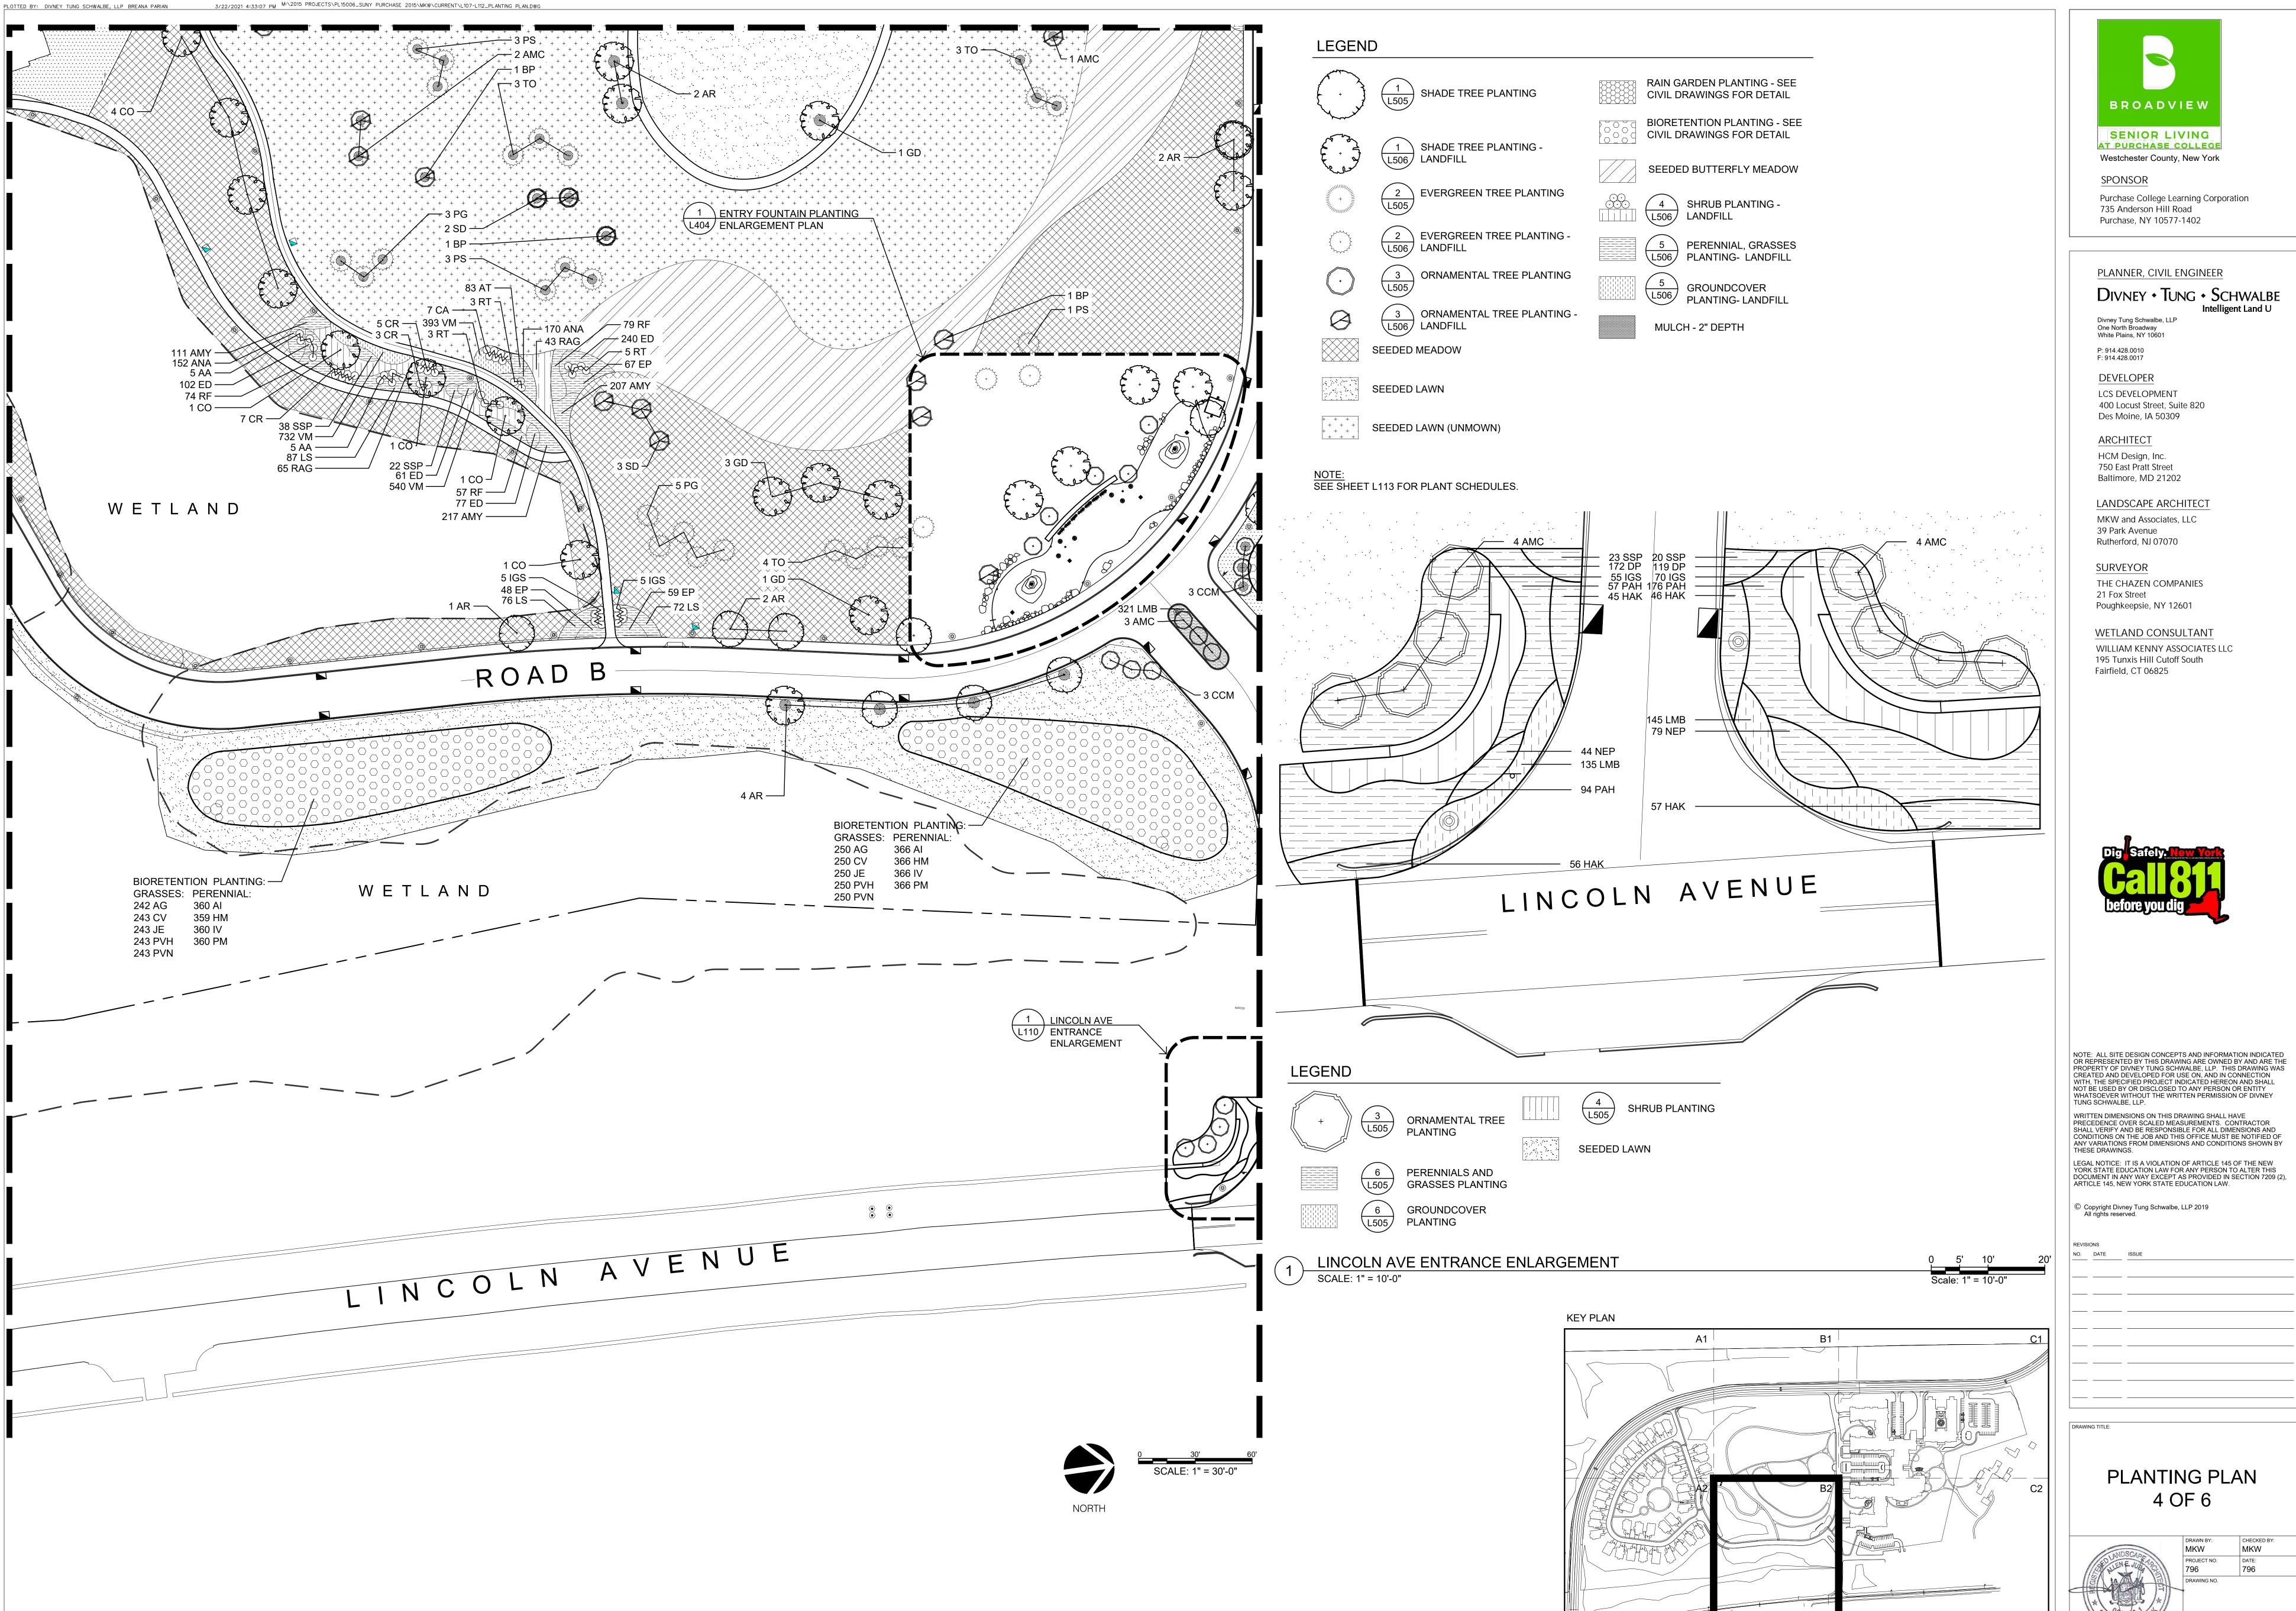



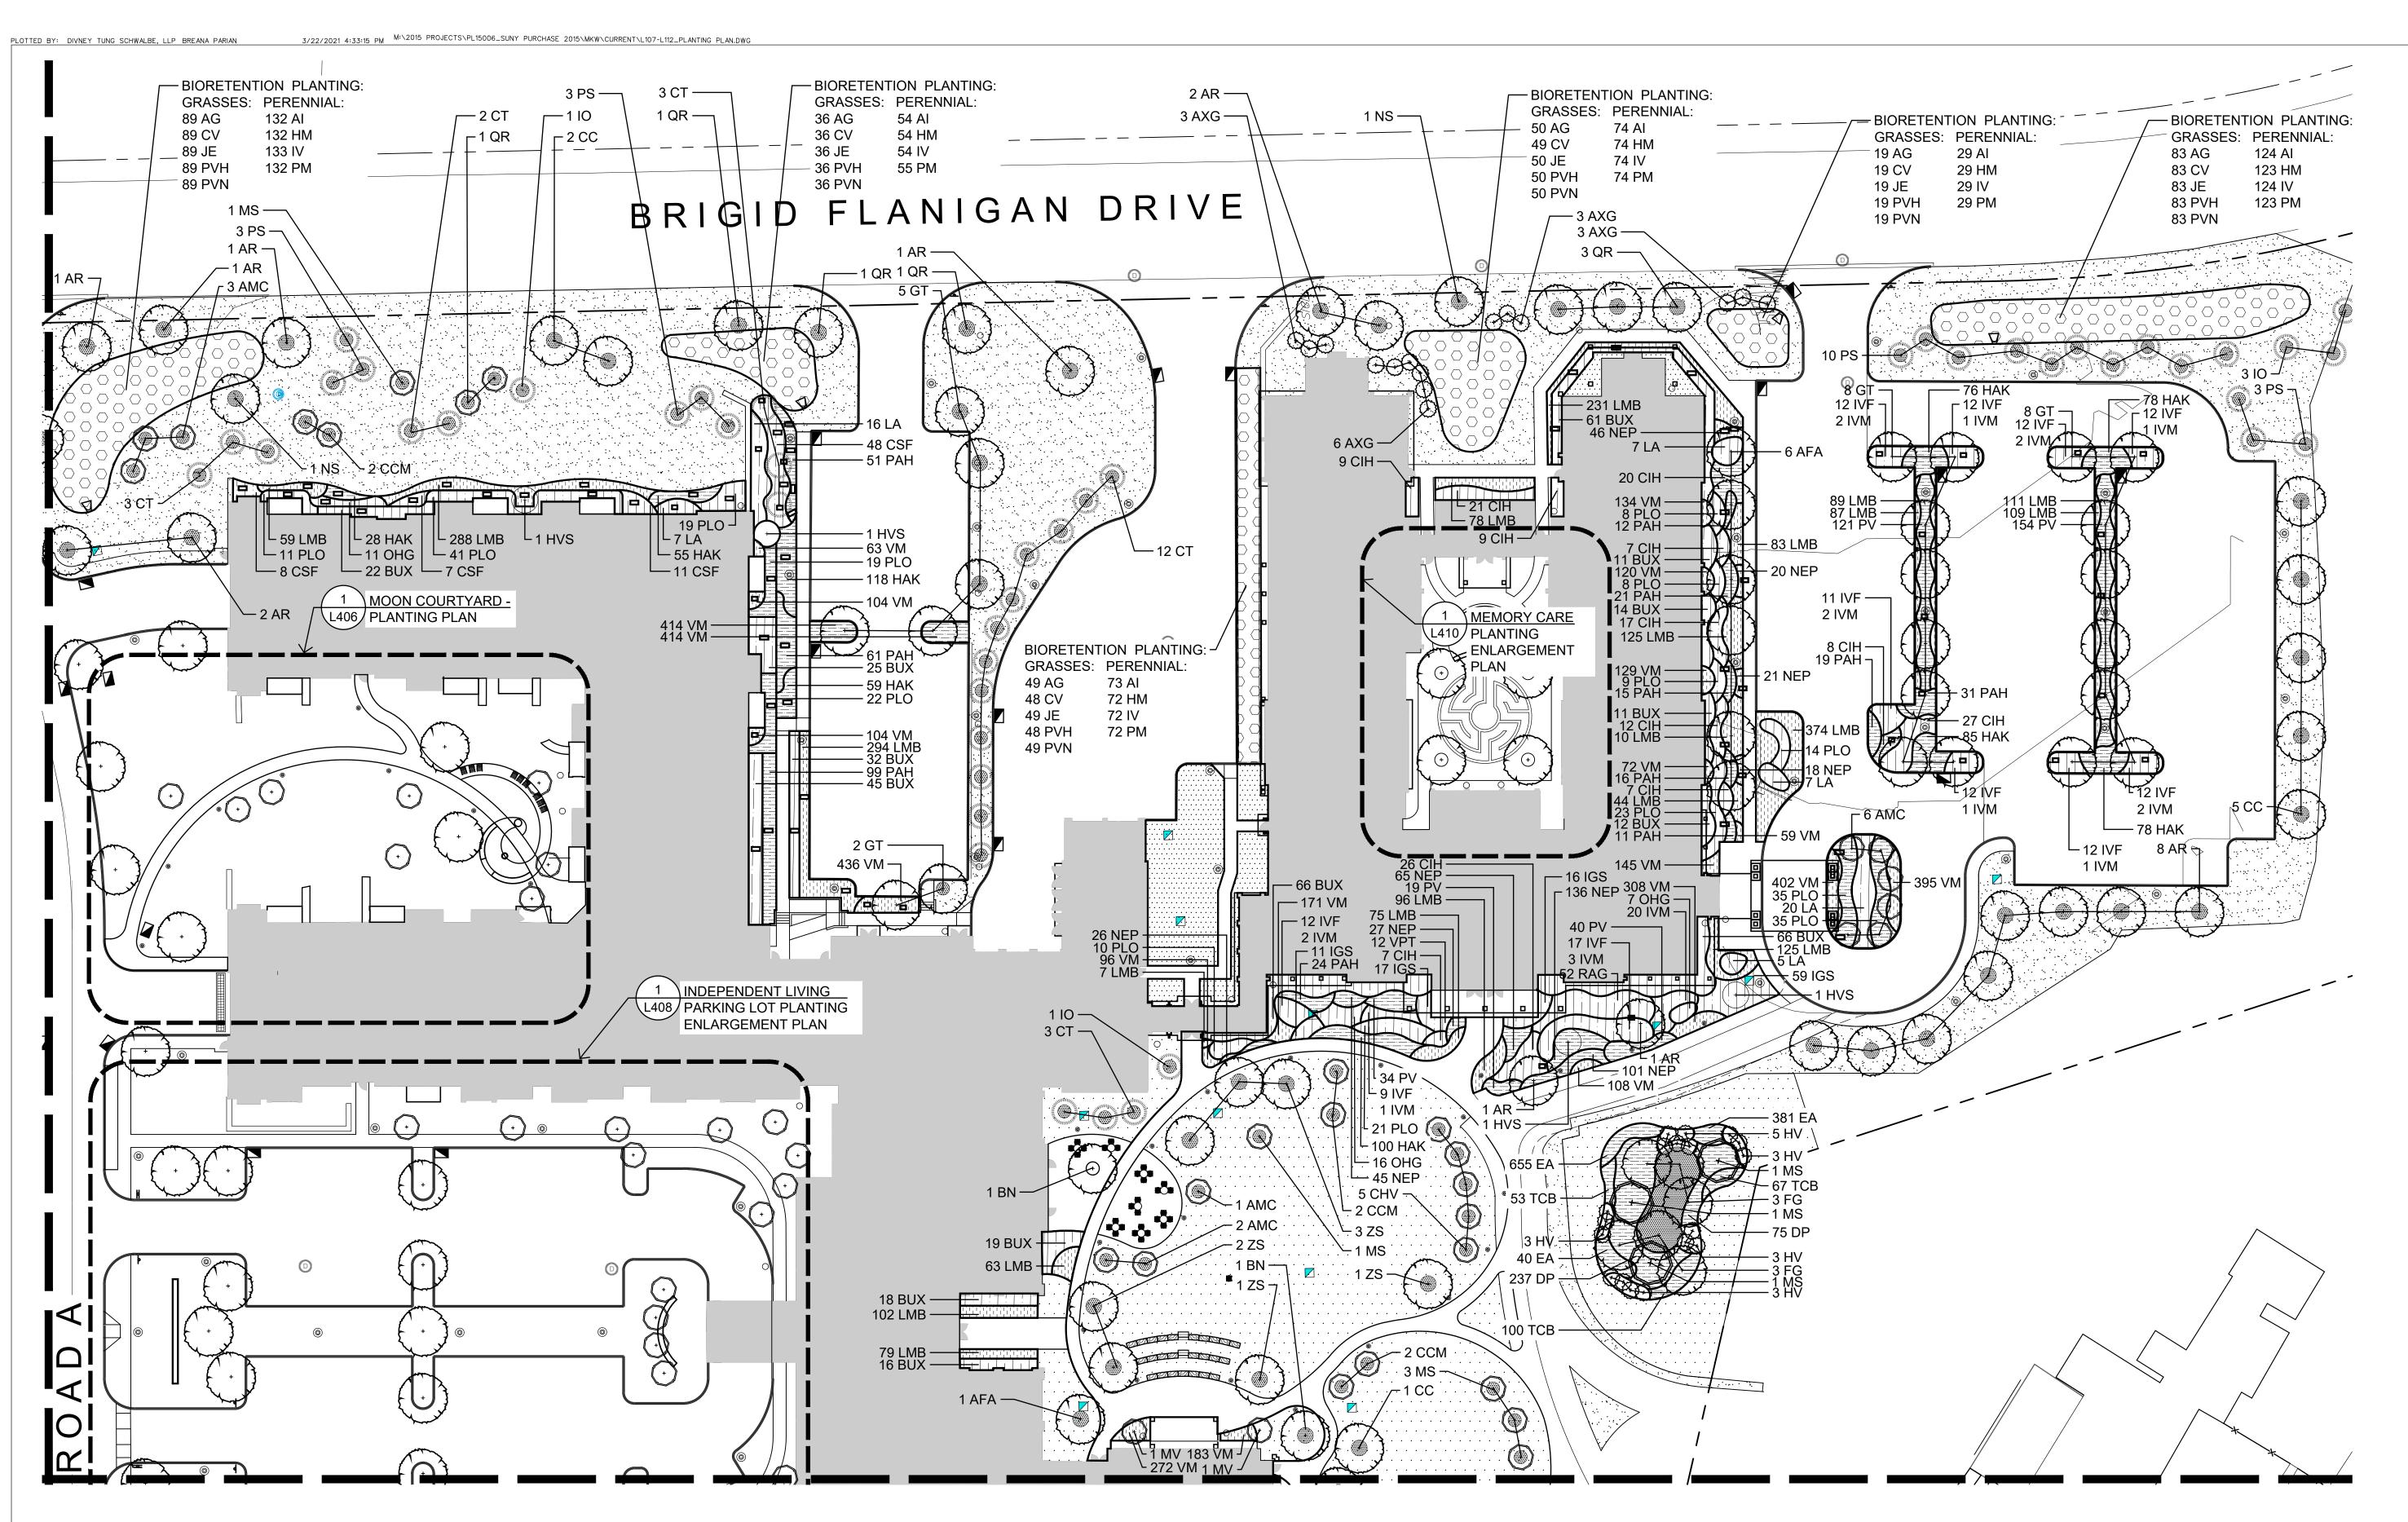




EVERGREEN TREE

RAIN GARDEN PLANTING - SEE CIVIL DRAWINGS FOR DETAIL

BIORETENTION PLANTING - SEE

CIVIL DRAWINGS FOR DETAIL

 MULCH - 2" DEPTH



L505 PLANTING PERENNIALS AND L505/ GRASSES PLANTING

 
GROUNDCOVER L505 PLANTING

NOTES:

1. SEE SHEET L113 FOR PLANT SCHEDULES.



KEY PLAN



PLANTING PLAN 5 OF 6



SCALE: 1" = 300'

SURVEYOR THE CHAZEN COMPANIES 21 Fox Street Poughkeepsie, NY 12601

39 Park Avenue Rutherford, NJ 07070

WETLAND CONSULTANT WILLIAM KENNY ASSOCIATES LLC 195 Tunxis Hill Cutoff South Fairfield, CT 06825

BROADVIEW

SENIOR LIVING

AT PURCHASE COLLEGE

Westchester County, New York

735 Anderson Hill Road Purchase, NY 10577-1402

PLANNER, CIVIL ENGINEER

Divney Tung Schwalbe, LLP One North Broadway White Plains, NY 10601

P: 914.428.0010 F: 914.428.0017

DEVELOPER

ARCHITECT

HCM Design, Inc.

750 East Pratt Street

Baltimore, MD 21202

LANDSCAPE ARCHITECT

MKW and Associates, LLC

LCS DEVELOPMENT

Des Moine, IA 50309

400 Locust Street, Suite 820

Purchase College Learning Corporation

DIVNEY • TUNG • SCHWALBE

SPONSOR





NOTE: ALL SITE DESIGN CONCEPTS AND INFORMATION INDICATED OR REPRESENTED BY THIS DRAWING ARE OWNED BY AND ARE THE PROPERTY OF DIVNEY TUNG SCHWALBE, LLP. THIS DRAWING WAS CREATED AND DEVELOPED FOR USE ON, AND IN CONNECTION WITH, THE SPECIFIED PROJECT INDICATED HEREON AND SHALL NOT BE USED BY OR DISCLOSED TO ANY PERSON OR ENTITY WHATSOEVER WITHOUT THE WRITTEN PERMISSION OF DIVNEY TUNG SCHWALBE, LLP.

WRITTEN DIMENSIONS ON THIS DRAWING SHALL HAVE PRECEDENCE OVER SCALED MEASUREMENTS. CONTRACTOR SHALL VERIFY AND BE RESPONSIBLE FOR ALL DIMENSIONS AND CONDITIONS ON THE JOB AND THIS OFFICE MUST BE NOTIFIED OF ANY VARIATIONS FROM DIMENSIONS AND CONDITIONS SHOWN BY

LEGAL NOTICE: IT IS A VIOLATION OF ARTICLE 145 OF THE NEW YORK STATE EDUCATION LAW FOR ANY PERSON TO ALTER THIS DOCUMENT IN ANY WAY EXCEPT AS PROVIDED IN SECTION 7209 (2), ARTICLE 145, NEW YORK STATE EDUCATION LAW.

© Copyright Divney Tung Schwalbe, LLP 2019 All rights reserved.

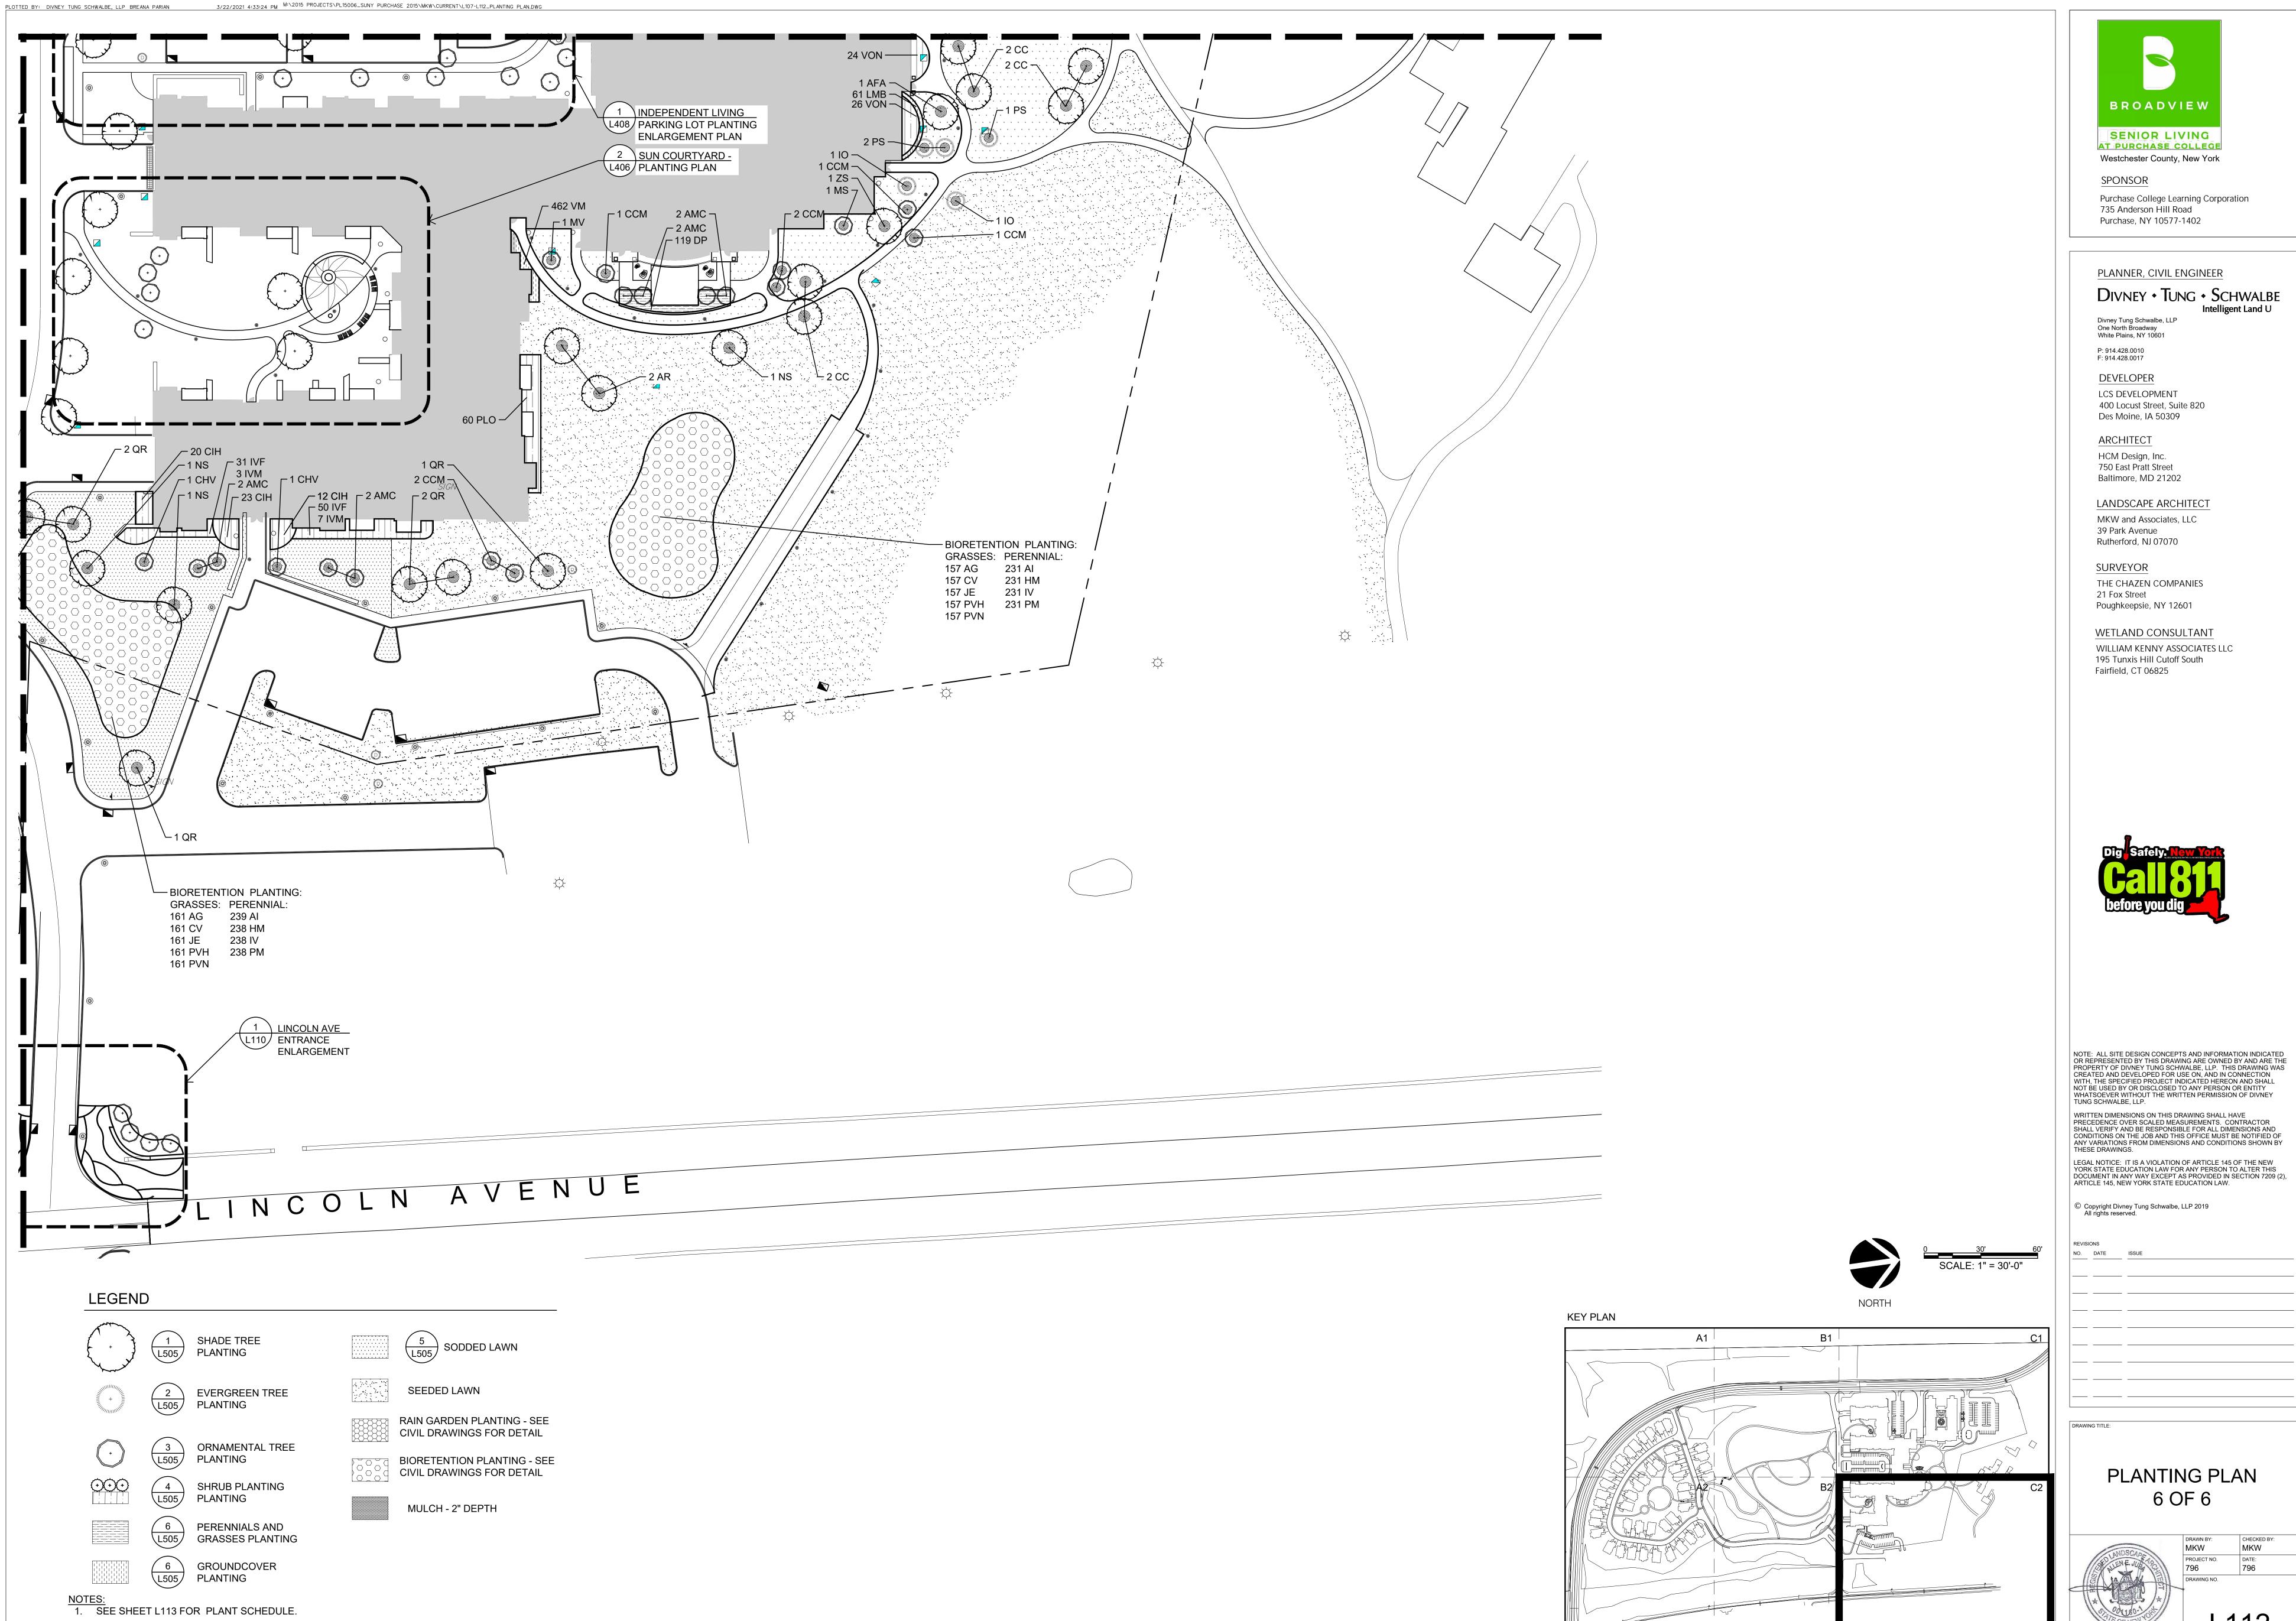

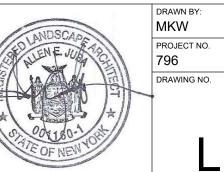

SCALE: 1" = 300'

	BY: DIVNEY TUNG SCHWALBE, LLP BREANA PARIAN 3/22/2021 4:33:31 PM M:\2015 PROJECTS\PL15006_SUNY PURCHASE 2015\MKW\CURRENT\L113_PLANTING SCHEDULE.DWG PLANT SCHEDULE						
QTY	KEY	BOTANICAL NAME	COMMON NAME	CAL./ HT.	ROOT	SPACING	COMMENTS
			COMMON NAME	CAL./ HT.	ROOT	SPACING	COMMENTS
SHADE			Padneinte Red Manla	2" 25" CAL	D O D	AC DED DI ANI	BRANCHED 6-7' FROM GROUND. SINGLE, STRAIGHT TRUNK WITH
37	AR	Acer rubrum 'Redpointe'	Redpointe Red Maple	2" - 2.5" CAL.	B&B	AS PER PLAN	LEADER INTACT AND SYMMETRICAL WELL-BRANCHED TOP
8	AFA	Acer x freemanii 'Armstrong'	Armstrong Freeman Maple	2" - 2.5" CAL.	B&B	AS PER PLAN	BRANCHED 6-7' FROM GROUND. SINGLE, STRAIGHT TRUNK WITH LEADER INTACT AND SYMMETRICAL WELL-BRANCHED TOP
2	BN	Betula nigra 'Dura Heat'	Dura Heat River Birch	8' - 10' HT.	B&B	AS PER PLAN	CLUMP FORM HAVING 3 OR MORE MAIN STEMS ARISING FROM THE MAIN TRUNK, NOT MORE THAN 6" FROM GROUND LEVEL.
33	СС	Carpinus caroliniana	American Hornbeam	2" - 2.5" CAL.	В&В	AS PER PLAN	STRAIGHT TRUNK WITH SYMMETRICAL, WELL-BRANCHED TOP. NO LIMB CUTS OVER 3/4" WHICH HAVE NOT COMPLETELY CALLUSED OVER.
6	FG	Fagus grandifolia	American Beech	2" - 2.5" CAL.	В&В	AS PER PLAN	BRANCHED 6-7' FROM GROUND. SINGLE, STRAIGHT TRUNK WITH LEADER INTACT AND SYMMETRICAL WELL-BRANCHED TOP
12	GB	Ginkgo biloba 'Magyar'	Maidenhair Tree	2" - 2.5" CAL.	B&B	AS PER PLAN	BRANCHED 6-7' FROM GROUND, AVERAGE HEIGHT 12-14'. SINGLE STRAIGHT TRUNK WITH LEADER INTACT, AND SYMMETRICAL, WELL-BRANCHED TOP
23	GT	Gleditsia triacanthos 'Skyline'	Skyline Honeylocust	2" - 2.5" CAL.	B&B	AS PER PLAN	BRANCHED 6-7' FROM GROUND, AVERAGE HEIGHT 11-12'. SPREAD OF TOP 4-5'.
5	NS	Nyssa sylvatica	Blackgum	2" - 2.5" CAL.	B&B	AS PER PLAN	BRANCHED 6-7' FROM GROUND, AVERAGE HEIGHT 11-12'.
23	QR	Quercus rubra	Northern Red Oak	2" - 2.5" CAL.	B&B	AS PER PLAN	BRANCHED 6-7' FROM GROUND, AVERAGE HEIGHT OF 11-12'. SPREAD OF TOP 4-5'.
33	ZS	Zelkova serrata 'Village Green'	Village Green Japanese Zelkova	2" - 2.5" CAL.	B&B	AS PER PLAN	BRANCHED 6' FROM GROUND, SPREAD OF TOP 4-5'.
EVERG	REEN	TREES					
20	СТ	Chamaecyparis thyoides	Atlantic White Cedar	8' - 10' HT.	B&B	AS PER PLAN	HEAVY AND WELL-BRANCHED.
33	Ю	Ilex opaca	American Holly	8' - 10' HT.	B&B	AS PER PLAN	HEAVY AND WELL-BRANCHED. ONE MALE PER FIVE FEMALE TREES.
53	PS	Pinus strobus	Eastern White Pine	6' - 7' HT.	B&B	AS PER PLAN	VIGOROUS, SINGLE STEM. NO LIMB CUTS OVER 3/4" WHICH HAVE NOT COMPLETELY CALLUSED OVER.
40	PT	Pinus thunbergii	Japanese Black Pine	6' - 7' HT.	B&B	AS PER PLAN	VIGOROUS, SINGLE STEM.
ORNAN	/IENTAL	TREES					
37	AMC	Amelanchier canadensis	Serviceberry	2" - 2.5" CAL.	B&B	AS PER PLAN	MINIMUM OF 4 MAIN STEMS.
19		Cercis canadensis 'Merlot'	Eastern Redbud	5' - 6' HT.	B&B	AS PER PLAN	VIGOROUS, SINGLE STEM, SYMMETRICAL.
9		Chionanthus virginicus	Fringetree	6' - 7' HT.	B&B B&B	AS PER PLAN AS PER PLAN	VIGOROUS, SINGLE STEM, SYMMETRICAL. HEAVY, WELL-BRANCHED TOP.
5		Hamemalis vernalis 'Sandra' Magnolia virginiana	Ozark Witch Hazel Sweetbay Magnolia	15" - 18" HT. 6' - 7' HT.	B&B B&B	AS PER PLAN	VIGOROUS, SINGLE STEM, SYMMETRICAL.
10		Magnolia stellata 'Royal Star'	Royal Star Magnolia	5' - 6' HT.	B&B	AS PER PLAN	HEAVY, WELL-BRANCHED TOP.
DECID	JOUS S	SHRUBS	1 -				
48	AA	Aronia arbutifolia 'Brilliantissima'	Red Chokeberry	36" - 48" HT.	B&B OR CONTAINER	36" O.C.	SYMMETRICAL WITH HEAVY, WELL-BRANCHED TOP.
350	CIH	Cornus alba 'Ivory Halo'	Variegated Redtwig Dogwood	12" - 15" HT.	B&B OR CONTAINER	36" O.C.	VIGOROUS, DENSE, SYMMETRICAL.
74	CSF	Cornus stolonifera 'Farrow'	Red Twig Dogwood	12" - 15" HT.	B&B OR CONTAINER	36" O.C.	VIGOROUS, DENSE, SYMMETRICAL.
110	FO	Fothergilla gardenii	Dwarf Fothergilla	18" - 24" HT.	B&B OR CONTAINER	30" O.C.	VIGOROUS, DENSE, SYMMETRICAL.
17	HV	Hamamelis vernalis 'Arnold's Promise'	Witch Hazel	3' - 4' HT.	B&B OR CONTAINER	AS PER PLAN	HEAVY, WELL-BRANCHED TOP.
27	HQ	Hydrangea quercifolia 'Gatsby Pink'	Oakleaf Hydrangea	12" - 15" HT.	B&B OR CONTAINER	AS PER PLAN	VIGOROUS, SYMMETRICAL.
360	IVF	llex verticillata 'FarrowBPop' (female)	Berry Poppins Winterberry Holly	15" - 18" HT.	B&B OR CONTAINER	36" O.C.	VIGOROUS, DENSE, SYMMETRICAL.
62	IVM	llex verticillata 'FarrowMrP' (male)	Mr.Poppins Winterberry Holly	15" - 18" HT.	B&B OR CONTAINER	36" O.C.	VIGOROUS, DENSE, SYMMETRICAL.
129	IVH	Itea virginica 'Little Henry'	Sweetspire	12" - 15" HT.	B&B OR CONTAINER	36" O.C.	VIGOROUS, DENSE, SYMMETRICAL
123 118	LA RAG	Lindera angustifolia Rhus aromatica 'Gro-Low'	Oriental Spicebush Dwarf Fragrant Sumac	12" - 15" HT. 12" - 15" HT.	B&B OR CONTAINER B&B OR CONTAINER	48" O.C. 36" O.C.	VIGOROUS, DENSE, SYMMETRICAL. VIGOROUS, DENSE, LOW.
70	RR	Rosa rugosa 'Meitozaure'	Rugostar Raspberry Rose	12 - 15 111. 12" - 15" HT.	B&B OR CONTAINER	AS PER PLAN	VIGOROUS, DENSE, FREE OF DISEASE.
235	VON	Viburnum opulus 'Nanum'	European Cranberry Bush	18" - 24" HT.	B&B OR CONTAINER	36" O.C.	WELL-BRANCHED TOP WITH AT LEAST 4 STEMS
12	VPT	Viburnum plicatum tom. 'Shasta'	Doublefire Viburnum	24"-36" HT.	B&B OR CONTAINER	36" O.C.	WELL-BRANCHED TOP WITH AT LEAST 4 STEMS
EVERG	REEN	SHRUBS					
80	AXG	Abelia x grandiflora	Glossy Abelia	15" - 18" HT.	CONTAINER	AS PER PLAN	WELL-ESTABLISHED IN CONTAINER
418	BUX	Buxus semipervirens 'Suffruticosa'	Compact Boxwood	12" - 15" HT.	CONTAINER	36" O.C.	WELL-ESTABLISHED IN CONTAINER
166	IGS	Ilex glabra 'Shamrock' Osmanthus heterophyllus 'Goshiki'	Shamrock Inkberry Holly Goshiki False Holly	18" - 24" HT.	CONTAINER	30" O.C.	WELL-ESTABLISHED IN CONTAINER
89 489	OHG PLO	Prunus laurocerasus 'Otto Luyken'	Cherry Laurel	15" - 18" HT. 15" - 18" HT.	CONTAINER CONTAINER	36" O.C.	WELL-ESTABLISHED IN CONTAINER WELL-ESTABLISHED IN CONTAINER
PEREN			S, Eddio!	10 - 10 171.	JONIAMEN	J 00 0.0.	WELL LOW ADDITION OF THE CONTRIBUTY
1076	EA	Erythronium americanum	Fawn Lily	1 GAL	CONTAINER	6" O.C.	WELL-ESTABLISHED IN CONTAINER
431	DP	Dennstaedtia punctilobula	Hay-Scented Fern	1 GAL	CONTAINER	24" O.C.	WELL-ESTABLISHED IN CONTAINER
505	NEP	Nepeta faasenii	Catnip	1 GAL	CONTAINER	15" O.C.	WELL-ESTABLISHED IN CONTAINER
220	ТСВ	Tiarella cordifolia "Brandywine"	Foam Flower	1 GAL	CONTAINER	15" O.C.	WELL-ESTABLISHED IN CONTAINER
GRASS							
677	HAK	Hakonechloa macra	Japanese Forest Grass	1 GAL.	CONTAINER	18" O.C.	WELL-ESTABLISHED IN CONTAINER
368	PV	Panicum virgatum 'Northwind"	Northwind Switchgrass	2 GAL.	CONTAINER	24" O.C.	WELL-ESTABLISHED IN CONTAINER
360 GROUN		Pennisetum alopecurides 'Hameln' ER	Fountain Grass	2 GAL	CONTAINER	24" O.C.	WELL-ESTABLISHED IN CONTAINER
2690	LMB	Liriope muscari 'Big Blue'	Big Blue Lilyturf	1 GAL.	CONTAINER	15" O.C.	WELL-ESTABLISHED IN CONTAINER
15964	VM	Vinca minor	Periwinkle	FLAT	CONTAINER	3/SF	WELL-ESTABLISHED IN CONTAINER
						-	

BIORETENTION PLANT SCHEDULE

QTY	KEY	BOTANICAL NAME	COMMON NAME	CAL./ HT.	ROOT	SPACING	COMMENTS
PEREN	PERENNIALS						
1530	AG	Andropogon gerardii	Big Bluestem	1 GAL.	CONTAINER	24" O.C.	WELL-ESTABLISHED IN CONTAINER.
2281	Al	Asclepias incarnata	Swamp Milkweed	1 GAL.	CONTAINER	18" O.C.	WELL-ESTABLISHED IN CONTAINER.
1499	CV	Carex vulpinoidea	Fox Sedge	1 GAL.	CONTAINER	24" O.C.	WELL-ESTABLISHED IN CONTAINER.
2217	НМ	Hibiscus moscheutos	Swamp Rose Mallow	2 GAL.	CONTAINER	18" O.C.	WELL-ESTABLISHED IN CONTAINER.
2279	IV	Iris versicolor	Blue Flag Iris	2 GAL.	CONTAINER	18" O.C.	WELL-ESTABLISHED IN CONTAINER.
1533	JE	Juncus effusus	Soft Rush	2 GAL.	CONTAINER	24" O.C.	WELL-ESTABLISHED IN CONTAINER.
1529	PVH	Panicum virgatum 'Shenandoah'	Shenandoah Switchgrass	3 GAL.	CONTAINER	24" O.C.	WELL-ESTABLISHED IN CONTAINER.
1530	PVN	Panicum virgatum 'North Wind'	North Wind Switchgrass	3 GAL.	CONTAINER	24" O.C.	WELL-ESTABLISHED IN CONTAINER.
2278	PM	Pycnanthemum muticum	Mountain Mint	1 QRT.	CONTAINER	18" O.C.	WELL-ESTABLISHED IN CONTAINER.

LANDAADIZ DI ANT COLIEDIU E

LAND	OMAF	RK PLANT SCHED	ULE				
QTY	KEY	BOTANICAL NAME	COMMON NAME	CAL./ HT.	ROOT	SPACING	COMMENTS
SHADE	L TREE:	<u>. </u>		<u> </u>			
19	AR	Acer rubrum 'Redpointe'	Redpointe Red Maple	2" - 2.5" CAL.	B&B	AS PER PLAN	BRANCHED 6-7' FROM GROUND. SINGLE, STRAIGHT TRUNK WITH LEADER INTACT AND SYMMETRICAL WELL-BRANCHED TOP
24	CE	Celtis occidentalis	Hackberry	2" - 2.5" CAL.	B&B	AS PER PLAN	BRANCHED 6-7' FROM GROUND, AVERAGE HEIGHT 12-14'. STRAIGHT TRUNK WITH SYMMETRICAL, WELL-BRANCHED TOP. SPREAD OF TOP 5-6'.
16	GD	Gymnocladus dioicus	Kentucky Coffee Tree	2" - 2.5" CAL.	B&B	AS PER PLAN	BRANCHED 6-7' FROM GROUND, AVERAGE HEIGHT OF 11-12'. SPREAD OF TOP 4-5'.
7	QP	Quercus palustris	Pin Oak	2" - 2.5" CAL.	B&B	AS PER PLAN	BRANCHED 6-7' FROM GROUND, AVERAGE HEIGHT OF 11-12'. SPREAD OF TOP 4-5'.
1	QR	Quercus rubra	Northern Red Oak	2" - 2.5" CAL.	B&B	AS PER PLAN	BRANCHED 6-7' FROM GROUND, AVERAGE HEIGHT OF 11-12'. SPREAD OF TOP 4-5'.
EVERG	BREEN	TREES					
25	PG	Picea glauca	White Spruce	6' - 7' HT.	B&B	AS PER PLAN	VIGOROUS, SINGLE STEM. NO LIMB CUTS OVER 3/4" WHICH HAVE NOT COMPLETELY CALLUSED OVER.
21	PS	Pinus strobus	Eastern White Pine	6' - 7' HT.	B&B	AS PER PLAN	VIGOROUS, SINGLE STEM. NO LIMB CUTS OVER 3/4" WHICH HAVE NOT COMPLETELY CALLUSED OVER.
23	ТО	Thuja occidentalis	Arborvitae	6' - 7' HT.	B&B	AS PER PLAN	VIGOROUS, SINGLE STEM.
ORNAN	MENTAI	_ TREES					
15	AMC	Amelanchier canadensis	Serviceberry	2" - 2.5" CAL.	B&B	AS PER PLAN	MINIMUM OF 4 MAIN STEMS.
7	BP	Betula populifolia	Grey Birch	5' - 6' HT.	B&B	AS PER PLAN	CLUMP FORM HAVING 3 OR MORE MAIN STEMS ARISING FROM THE MAIN TRUNK, NOT MORE THAN 6" FROM GROUND LEVEL.
6	ССМ	Cercis canadensis 'Merlot'	Eastern Redbud	5' - 6' HT.	B&B	AS PER PLAN	VIGOROUS, SINGLE STEM, SYMMETRICAL.
11	SD	Salix discolor	American Pussy Willow	3' - 6' HT.	B&B	AS PER PLAN	MINIMUM OF 4 MAIN STEMS.
DECID	UOUS S	SHRUBS	1	1			
28	AA	Aronia arbutifolia	Red Chokeberry	2 GAL.	B&B OR CONTAINER	AS PER PLAN	SYMMETRICAL WITH HEAVY, WELL-BRANCHED TOP.
25	AM	Aronia melanocarpa	Black Chokeberry	2 GAL.	B&B OR CONTAINER	AS PER PLAN	SYMMETRICAL WITH HEAVY, WELL-BRANCHED TOP.
77	CA	Clethra alnifolia	Summersweet	3 GAL.	B&B OR CONTAINER	AS PER PLAN	WELL-ESTABLISHED
50	CR	Cornus racemosa	Gray Dogwood	2 GAL.	B&B OR CONTAINER	AS PER PLAN	MINIMUM OF 4 MAIN STEMS.
104	IVF	llex verticillata 'FarrowBPop' (female)	Berry Poppins Winterberry Holly	15" - 18" HT.	B&B OR CONTAINER	36" O.C.	VIGOROUS, DENSE, SYMMETRICAL.
15	IVM	llex verticillata 'FarrowMrP' (male)	Mr.Poppins Winterberry Holly	15" - 18" HT.	B&B OR CONTAINER	36" O.C.	VIGOROUS, DENSE, SYMMETRICAL.
42	IVH	Itea virginica 'Henry's Garnet'	Sweetspire	12" - 15" HT.	B&B OR CONTAINER	36" O.C.	VIGOROUS, DENSE, SYMMETRICAL.
644	RAG	Rhus aromatica 'Gro-Low'	Gro-Low Sumac	3 GAL.	B&B OR CONTAINER	36" O.C.	VIGOROUS, DENSE, LOW.
47	RT	Rhus typhina 'Laciniata'	Staghorn Sumac	18" - 24" HT.	B&B OR CONTAINER	AS PER PLAN	MINIMUM OF 4 MAIN STEMS.
EVERG	REEN	SHRUBS	•	•			
16	IGS	llex glabra 'Shamrock'	Shamrock Inkberry Holly	18" - 24" HT.	CONTAINER	30" O.C.	WELL-ESTABLISHED IN CONTAINER
12	MP	Myrica pensylvanica	Northern Bayberry	3 GAL.	B&B OR CONTAINER	AS PER PLAN	WELL-ESTABLISHED IN CONTAINER
PEREN	INIALS						
1771	AMY	Achillea millefolium	Yarrow	FLAT	CONTAINER	12" O.C.	WELL-ESTABLISHED IN CONTAINER.
545	AT	Asclepias tuberosa	Butterfly Weed	1 GAL.	CONTAINER	12" O.C.	WELL-ESTABLISHED IN CONTAINER.
1157	ANA	Aster novi-angliae	New England Aster	FLAT	CONTAINER	12" O.C.	WELL-ESTABLISHED IN CONTAINER.
775	EP	Echinacea purpurea	Purple Coneflower	3 GAL.	CONTAINER	18" O.C.	WELL-ESTABLISHED IN CONTAINER.
811	ED	Eupatorium dubium 'Baby Joe'	Baby Joe Pye Weed	1 GAL.	CONTAINER	12" O.C.	WELL-ESTABLISHED IN CONTAINER.
1076	LS	Liatris spicata	Blazing Stars	1 GAL.	CONTAINER	18" O.C.	WELL-ESTABLISHED IN CONTAINER.
520	RF	Rudbeckia fulgida 'Goldsturm'	Black Eyed Susan	2 GAL.	CONTAINER	18" O.C.	WELL-ESTABLISHED IN CONTAINER.
426	SSP	Solidago sempervirens	Seaside Goldenrod	1 GAL.	CONTAINER	18" O.C.	WELL-ESTABLISHED IN CONTAINER.
EVERG	BREEN	GROUNDCOVER					
321	LMB	Liriope muscari 'Big Blue'	Big Blue Lilyturf	1 GAL.	CONTAINER	15" O.C.	WELL-ESTABLISHED IN CONTAINER
			1	+	1		

LANDMARK SEED MIX SCHEDULE

LBS	SEED MIX	MIX NUMBER	RATE	ROOT
4.5	Butterfly Meadow Seed Mix	Ernmx 179	10 LBS/ ACRE	SEED
50	Meadow Seed Mix	Ernmx 122	20 LBS/ ACRE	SEED
625	Seeded Lawn Mix	Ernmx 113	100 LBS/ ACRE	SEED
400	Seeded No Mow Lawn Mix	Ernmx 113	100 LBS/ ACRE	SEED

RAIN GARDEN PLANT SCHEDULE

V VIII V	<u> </u>	DEITH LATIT CONLEGE	'				
QTY	KEY	BOTANICAL NAME	COMMON NAME	CAL./ HT.	ROOT	SPACING	COMMENTS
DECIDUOUS SHRUBS							
114	СО	Cephalanthus occidentalis	Buttonbush	2 GAL.	B&B OR CONTAINER	24" O.C.	HEAVY, WELL-BRANCHED TOP.
138	CA	Clethra alnifolia	Ruby Spice Pepperbush	15" - 18" HT.	B&B OR CONTAINER	24" O.C.	VIGOROUS, DENSE, SYMMETRICAL.
119	CS	Cornus stolonifera	Red-Osier Dogwood	36" - 72" HT.	B&B OR CONTAINER	24" O.C.	VIGOROUS, DENSE, SYMMETRICAL.
129	HV	Hamamelis virginiana	Witch Hazel	36" - 72" HT.	B&B OR CONTAINER	24" O.C.	VIGOROUS, DENSE, SYMMETRICAL.
133	IVF	llex verticillata (female)	Winterberry Holly	15" - 18" HT.	B&B OR CONTAINER	24" O.C.	VIGOROUS, DENSE, SYMMETRICAL.
19	IVM	llex verticillata (male)	Winterberry Holly	15" - 18" HT.	B&B OR CONTAINER	24" O.C.	VIGOROUS, DENSE, SYMMETRICAL.
114	VD	Viburnum dentatum	Arrowwood Viburnum	36" - 72" HT.	B&B OR CONTAINER	24" O.C.	VIGOROUS, DENSE, SYMMETRICAL.
EVERG	REEN :	SHRUBS	•	•			
145	IGS	llex glabra	Inkberry Holly	18" - 24" HT.	B&B OR CONTAINER	24" O.C.	VIGOROUS, DENSE, SYMMETRICAL.
PEREN	INIALS						
443	Al	Asclepias incarnata	Swamp Milkweek	1 GAL.	CONTAINER	18" O.C.	WELL-ESTABLISHED IN CONTAINER.
445	CV	Carex vulpinoidea	Fox Sedge	1 GAL.	CONTAINER	18" O.C.	WELL-ESTABLISHED IN CONTAINER.
445	НМ	Hibiscus moscheutos	Swamp Rose Mallow	2 GAL.	CONTAINER	18" O.C.	WELL-ESTABLISHED IN CONTAINER.
444	PVH	Panicum virgatum 'Shenandoah'	Shenandoah Switchgrass	3 GAL.	CONTAINER	18" O.C.	WELL-ESTABLISHED IN CONTAINER.
444	PM	Pycnanthemum muticum	Mountain Mint	1 QRT.	CONTAINER	18" O.C.	WELL-ESTABLISHED IN CONTAINER.
445	RF	Rudbeckia fulgida 'Goldsturm'	Black Eyed Susan	2 GAL.	CONTAINER	18" O.C.	WELL-ESTABLISHED IN CONTAINER.
443	SS	Schizachyrium scoparium 'Carousel'	Carousel Little Bluestem	2 GAL.	CONTAINER	18" O.C.	WELL-ESTABLISHED IN CONTAINER.



SENIOR LIVING AT PURCHASE COLLEGE Westchester County, New York

<u>SPONSOR</u>

Purchase College Learning Corporation 735 Anderson Hill Road Purchase, NY 10577-1402

PLANNER, CIVIL ENGINEER

DIVNEY • TUNG • SCHWALBE Intelligent Land U

Divney Tung Schwalbe, LLP One North Broadway White Plains, NY 10601

P: 914.428.0010 F: 914.428.0017

DEVELOPER

LCS DEVELOPMENT 400 Locust Street, Suite 820 Des Moine, IA 50309

<u>ARCHITECT</u> HCM Design, Inc. 750 East Pratt Street

39 Park Avenue Rutherford, NJ 07070

Baltimore, MD 21202 LANDSCAPE ARCHITECT MKW and Associates, LLC

SURVEYOR THE CHAZEN COMPANIES 21 Fox Street

Poughkeepsie, NY 12601

WETLAND CONSULTANT WILLIAM KENNY ASSOCIATES LLC 195 Tunxis Hill Cutoff South Fairfield, CT 06825



WRITTEN DIMENSIONS ON THIS DRAWING SHALL HAVE PRECEDENCE OVER SCALED MEASUREMENTS. CONTRACTOR SHALL VERIFY AND BE RESPONSIBLE FOR ALL DIMENSIONS AND CONDITIONS ON THE JOB AND THIS OFFICE MUST BE NOTIFIED OF ANY VARIATIONS FROM DIMENSIONS AND CONDITIONS SHOWN BY THESE DRAWINGS. LEGAL NOTICE: IT IS A VIOLATION OF ARTICLE 145 OF THE NEW YORK STATE EDUCATION LAW FOR ANY PERSON TO ALTER THIS DOCUMENT IN ANY WAY EXCEPT AS PROVIDED IN SECTION 7209 (2), ARTICLE 145, NEW YORK STATE EDUCATION LAW.


© Copyright Divney Tung Schwalbe, LLP 2019 All rights reserved.

ONS			

DATE	ISSUE	

PLANTING SCHEDULE



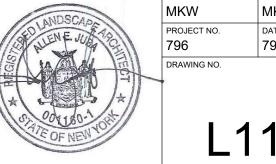



———— PROPERTY LINE

LIMIT OF WETLAND DISTURBANCE

KEY PLAN

LAWN IRRIGATION

PLANTING IRRIGATION



<u>SPONSOR</u>

Purchase College Learning Corporation

735 Anderson Hill Road

Purchase, NY 10577-1402

PLANNER, CIVIL ENGINEER

DIVNEY • TUNG • SCHWALBE

Divney Tung Schwalbe, LLP One North Broadway White Plains, NY 10601

P: 914.428.0010 F: 914.428.0017

DEVELOPER

LCS DEVELOPMENT 400 Locust Street, Suite 820 Des Moine, IA 50309

ARCHITECT

HCM Design, Inc. 750 East Pratt Street Baltimore, MD 21202

LANDSCAPE ARCHITECT MKW and Associates, LLC 39 Park Avenue Rutherford, NJ 07070

SURVEYOR

THE CHAZEN COMPANIES 21 Fox Street Poughkeepsie, NY 12601

WETLAND CONSULTANT

WILLIAM KENNY ASSOCIATES LLC 195 Tunxis Hill Cutoff South Fairfield, CT 06825



NOTE: ALL SITE DESIGN CONCEPTS AND INFORMATION INDICATED OR REPRESENTED BY THIS DRAWING ARE OWNED BY AND ARE THE PROPERTY OF DIVNEY TUNG SCHWALBE, LLP. THIS DRAWING WAS CREATED AND DEVELOPED FOR USE ON, AND IN CONNECTION WITH, THE SPECIFIED PROJECT INDICATED HEREON AND SHALL NOT BE USED BY OR DISCLOSED TO ANY PERSON OR ENTITY WHATSOEVER WITHOUT THE WRITTEN PERMISSION OF DIVNEY TUNG SCHWALBE, LLP.

WRITTEN DIMENSIONS ON THIS DRAWING SHALL HAVE PRECEDENCE OVER SCALED MEASUREMENTS. CONTRACTOR SHALL VERIFY AND BE RESPONSIBLE FOR ALL DIMENSIONS AND CONDITIONS ON THE JOB AND THIS OFFICE MUST BE NOTIFIED OF ANY VARIATIONS FROM DIMENSIONS AND CONDITIONS SHOWN BY THESE DRAWINGS.

LEGAL NOTICE: IT IS A VIOLATION OF ARTICLE 145 OF THE NEW YORK STATE EDUCATION LAW FOR ANY PERSON TO ALTER THIS DOCUMENT IN ANY WAY EXCEPT AS PROVIDED IN SECTION 7209 (2), ARTICLE 145, NEW YORK STATE EDUCATION LAW.

© Copyright Divney Tung Schwalbe, LLP 2019 All rights reserved.


IRRIGATION PLAN 1 OF 6



L114

SCALE: 1" = 300'

SCALE: 1" = 30'-0"

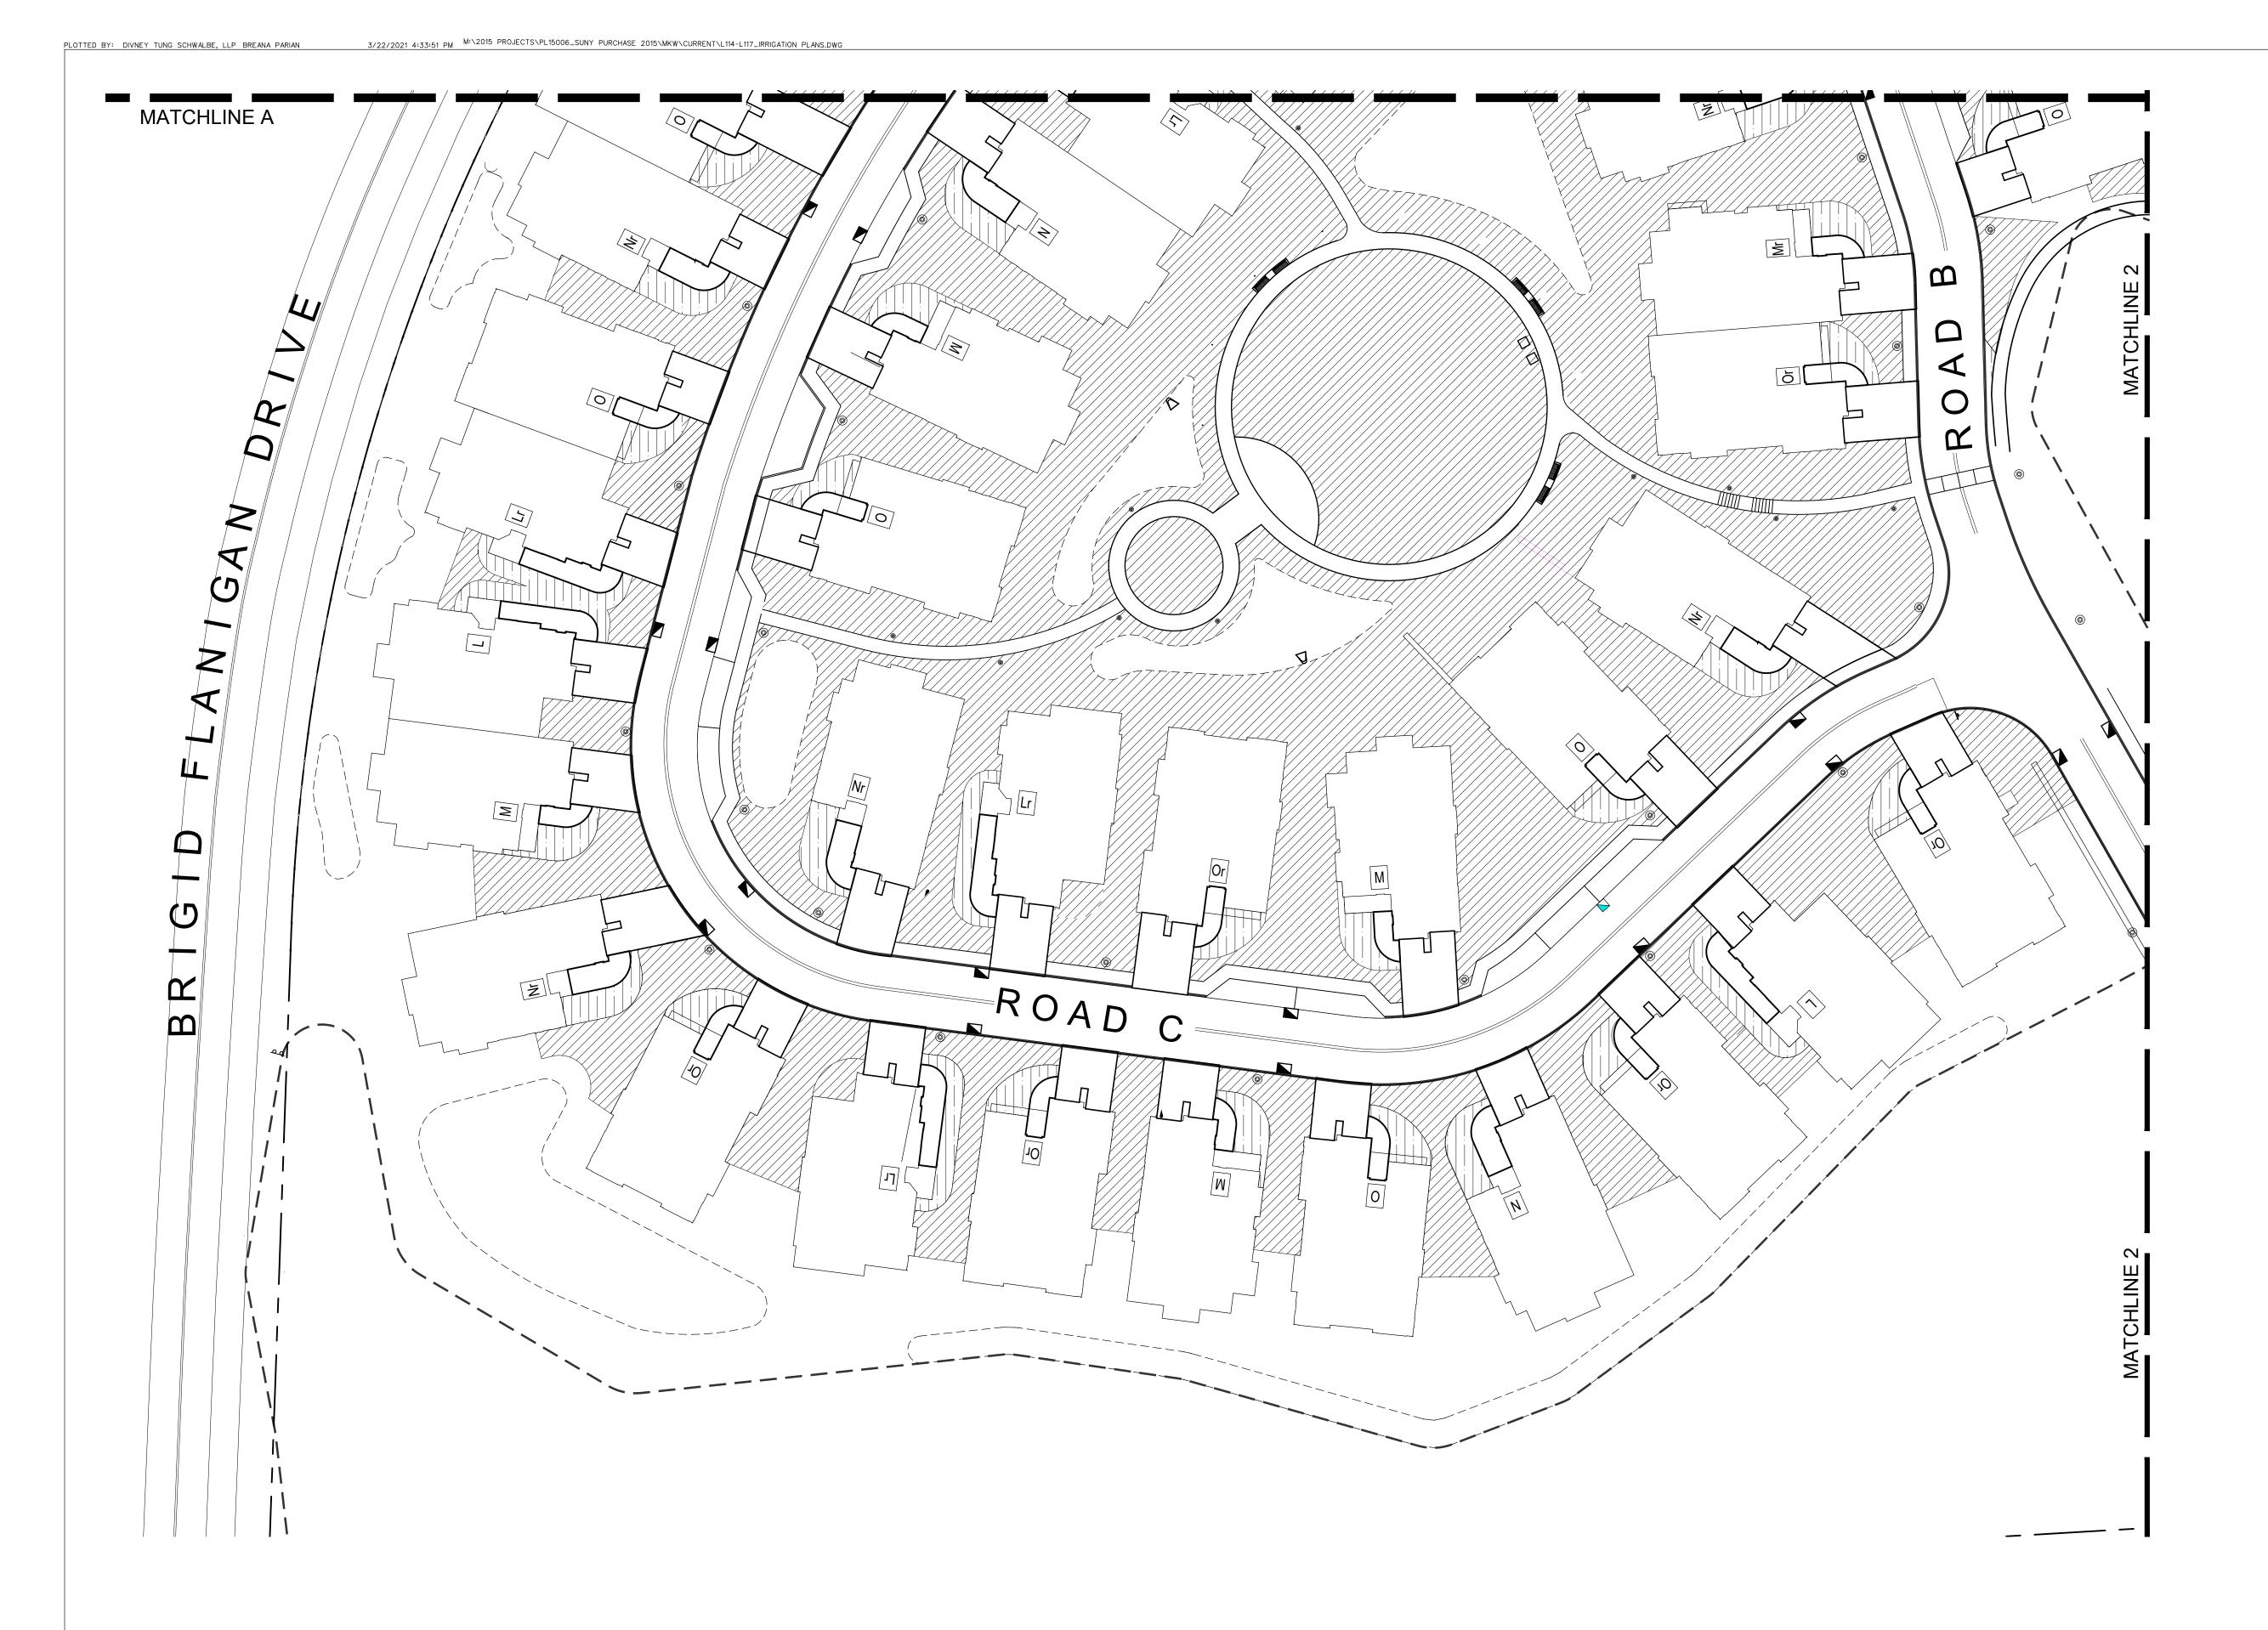

PROPERTY LINE

LIMIT OF WETLAND DISTURBANCE

LAWN IRRIGATION

PLANTING IRRIGATION



SENIOR LIVING AT PURCHASE COLLEGE Westchester County, New York

SPONSOR

Purchase College Learning Corporation 735 Anderson Hill Road Purchase, NY 10577-1402

PLANNER, CIVIL ENGINEER

DIVNEY • TUNG • SCHWALBE Intelligent Land U

Divney Tung Schwalbe, LLP One North Broadway White Plains, NY 10601

P: 914.428.0010 F: 914.428.0017

DEVELOPER LCS DEVELOPMENT

400 Locust Street, Suite 820 Des Moine, IA 50309

ARCHITECT HCM Design, Inc. 750 East Pratt Street

39 Park Avenue Rutherford, NJ 07070

Baltimore, MD 21202 LANDSCAPE ARCHITECT MKW and Associates, LLC

SURVEYOR

THE CHAZEN COMPANIES 21 Fox Street Poughkeepsie, NY 12601

WETLAND CONSULTANT WILLIAM KENNY ASSOCIATES LLC 195 Tunxis Hill Cutoff South Fairfield, CT 06825



NOTE: ALL SITE DESIGN CONCEPTS AND INFORMATION INDICATED OR REPRESENTED BY THIS DRAWING ARE OWNED BY AND ARE THE PROPERTY OF DIVNEY TUNG SCHWALBE, LLP. THIS DRAWING WAS CREATED AND DEVELOPED FOR USE ON, AND IN CONNECTION WITH, THE SPECIFIED PROJECT INDICATED HEREON AND SHALL NOT BE USED BY OR DISCLOSED TO ANY PERSON OR ENTITY WHATSOEVER WITHOUT THE WRITTEN PERMISSION OF DIVNEY TUNG SCHWALBE, LLP. WRITTEN DIMENSIONS ON THIS DRAWING SHALL HAVE PRECEDENCE OVER SCALED MEASUREMENTS. CONTRACTOR SHALL VERIFY AND BE RESPONSIBLE FOR ALL DIMENSIONS AND

CONDITIONS ON THE JOB AND THIS OFFICE MUST BE NOTIFIED OF ANY VARIATIONS FROM DIMENSIONS AND CONDITIONS SHOWN BY THESE DRAWINGS. LEGAL NOTICE: IT IS A VIOLATION OF ARTICLE 145 OF THE NEW YORK STATE EDUCATION LAW FOR ANY PERSON TO ALTER THIS DOCUMENT IN ANY WAY EXCEPT AS PROVIDED IN SECTION 7209 (2), ARTICLE 145, NEW YORK STATE EDUCATION LAW.

© Copyright Divney Tung Schwalbe, LLP 2019 All rights reserved.

REVISION	ONS	
NO.	DATE	ISSUE

IRRIGATION PLAN


2 OF 6

L115

SCALE: 1" = 300'

SCALE: 1" = 30'-0"

KEY PLAN

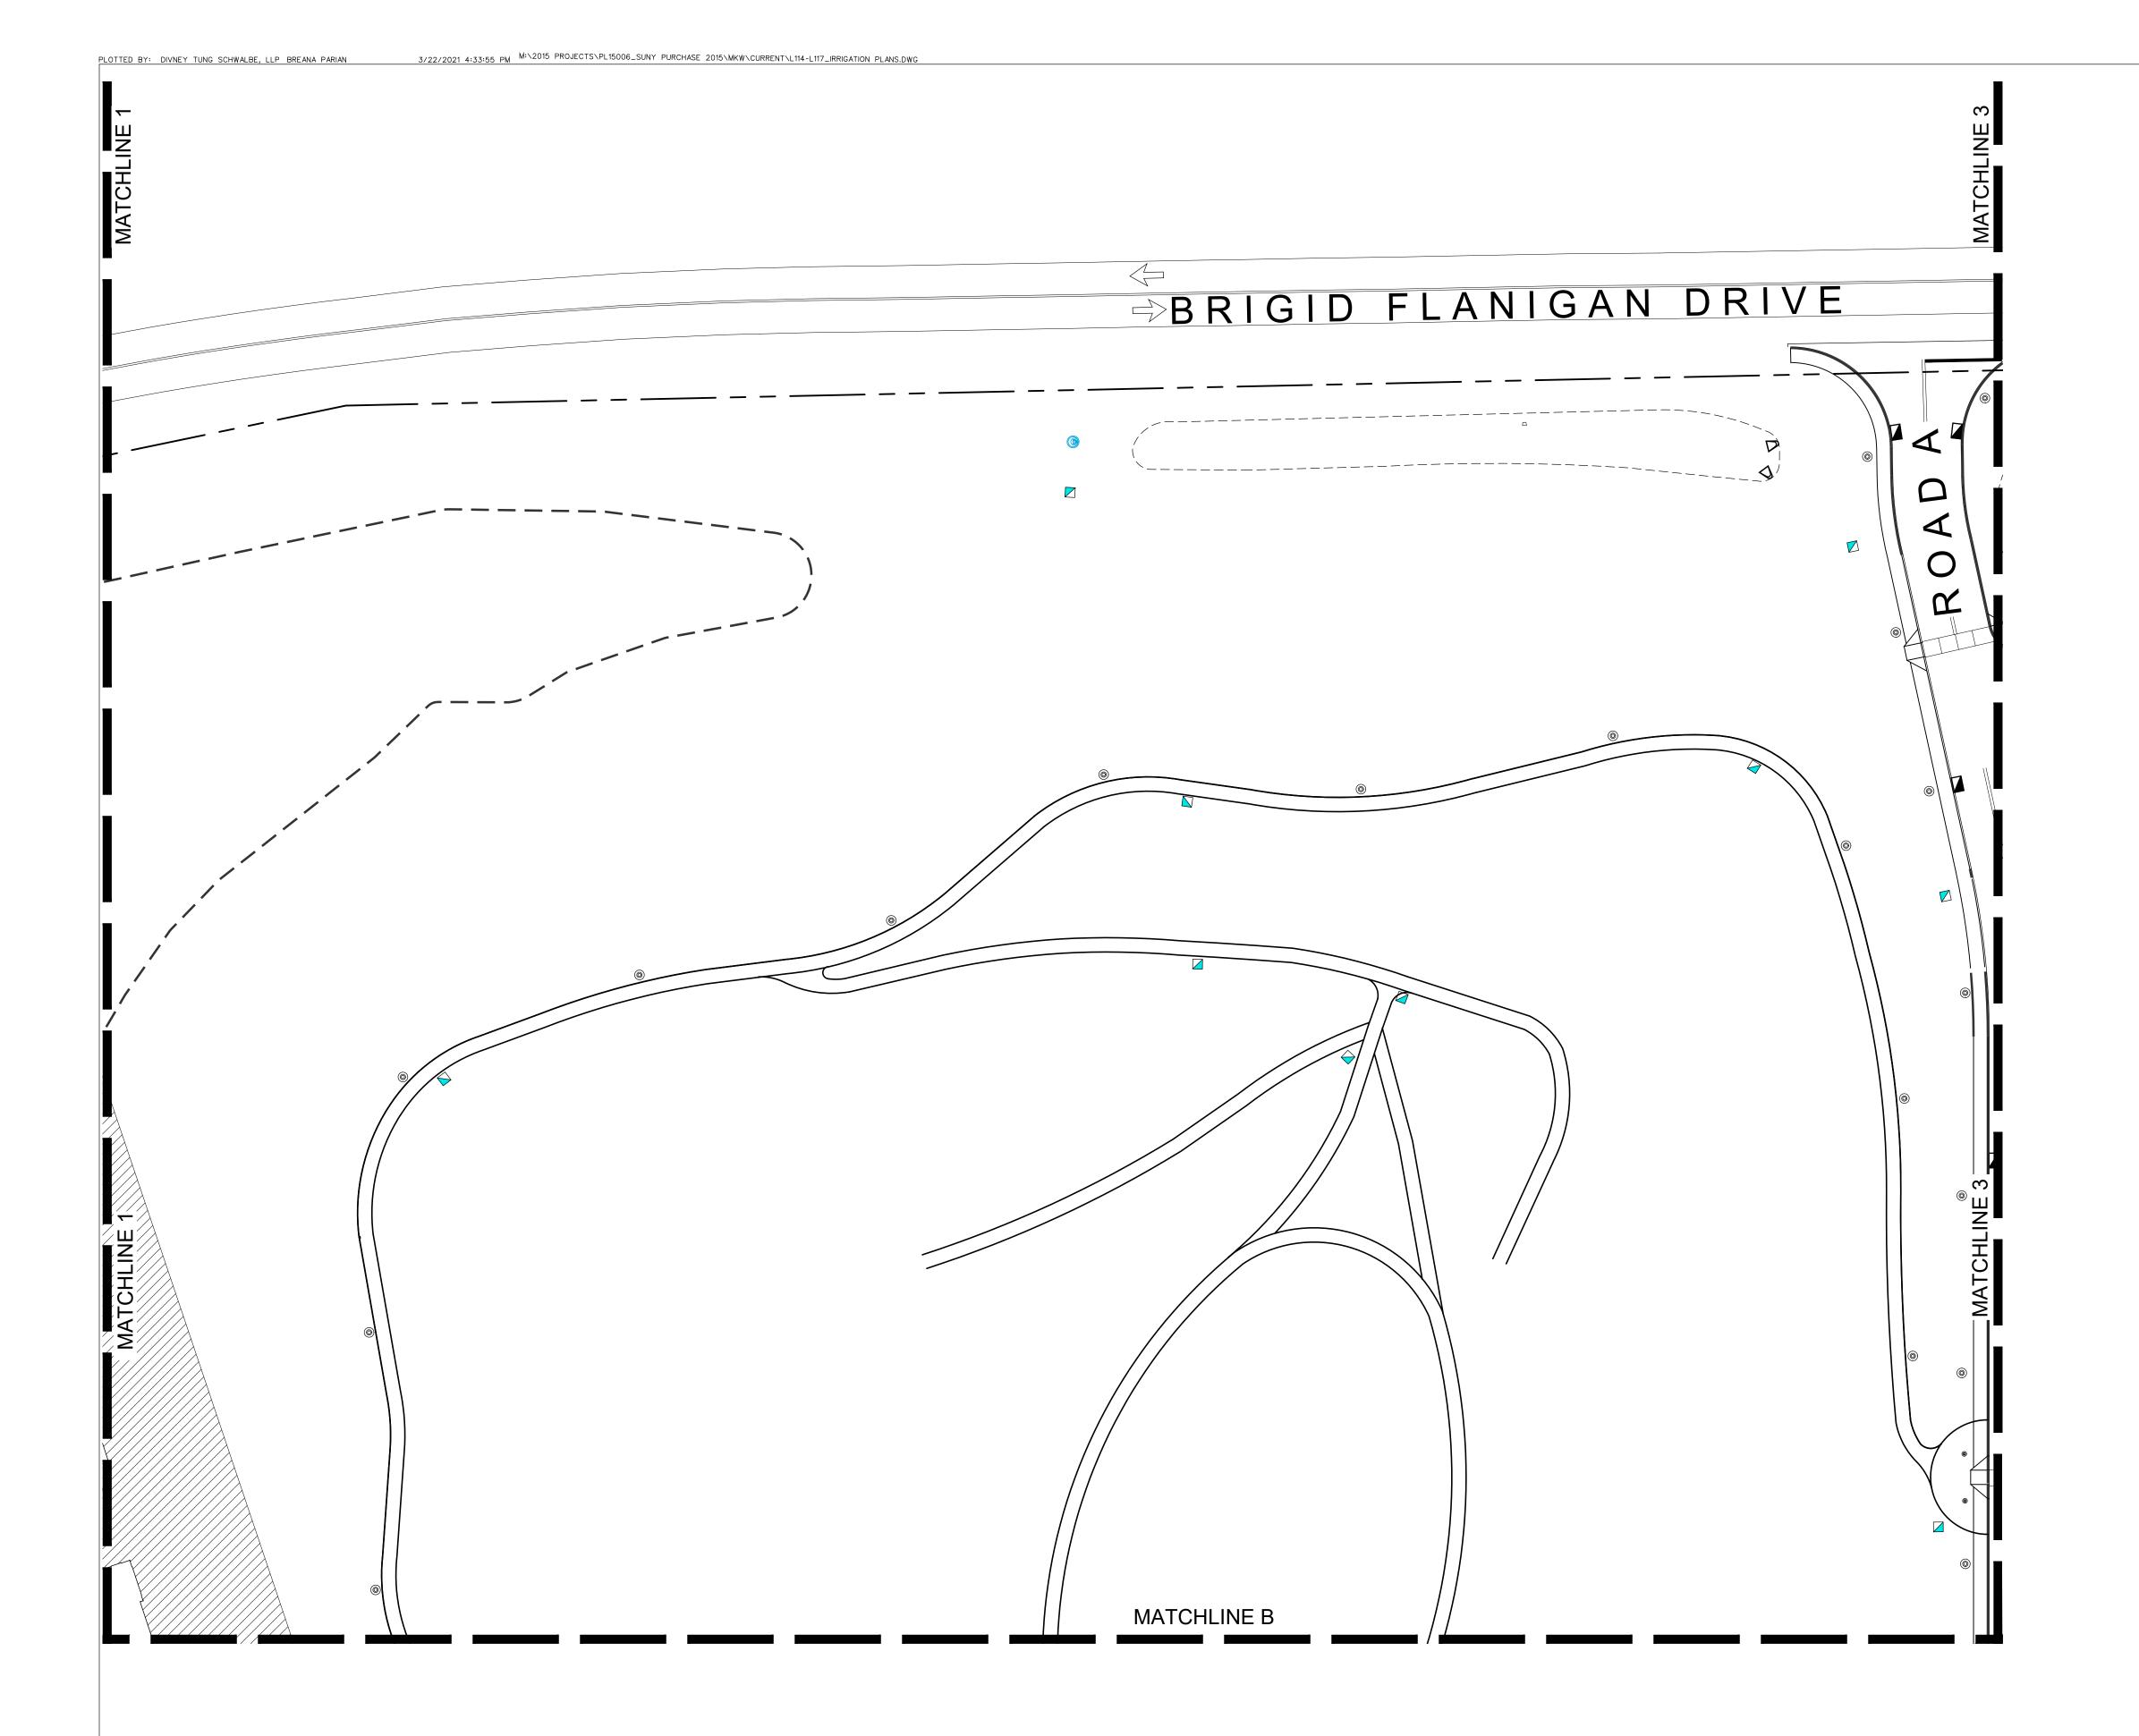

———— PROPERTY LINE

LIMIT OF WETLAND DISTURBANCE

KEY PLAN

LAWN IRRIGATION



SENIOR LIVING AT PURCHASE COLLEGE Westchester County, New York

<u>SPONSOR</u>

Purchase College Learning Corporation 735 Anderson Hill Road Purchase, NY 10577-1402

PLANNER, CIVIL ENGINEER

DIVNEY • TUNG • SCHWALBE Intelligent Land U

Divney Tung Schwalbe, LLP One North Broadway White Plains, NY 10601

P: 914.428.0010 F: 914.428.0017

DEVELOPER LCS DEVELOPMENT 400 Locust Street, Suite 820

<u>ARCHITECT</u>

Des Moine, IA 50309

HCM Design, Inc. 750 East Pratt Street Baltimore, MD 21202

LANDSCAPE ARCHITECT MKW and Associates, LLC 39 Park Avenue

SURVEYOR

Rutherford, NJ 07070

THE CHAZEN COMPANIES 21 Fox Street Poughkeepsie, NY 12601

WETLAND CONSULTANT WILLIAM KENNY ASSOCIATES LLC 195 Tunxis Hill Cutoff South Fairfield, CT 06825



NOTE: ALL SITE DESIGN CONCEPTS AND INFORMATION INDICATED OR REPRESENTED BY THIS DRAWING ARE OWNED BY AND ARE THE PROPERTY OF DIVNEY TUNG SCHWALBE, LLP. THIS DRAWING WAS CREATED AND DEVELOPED FOR USE ON, AND IN CONNECTION WITH, THE SPECIFIED PROJECT INDICATED HEREON AND SHALL NOT BE USED BY OR DISCLOSED TO ANY PERSON OR ENTITY WHATSOEVER WITHOUT THE WRITTEN PERMISSION OF DIVNEY TUNG SCHWALBE, LLP.


WRITTEN DIMENSIONS ON THIS DRAWING SHALL HAVE PRECEDENCE OVER SCALED MEASUREMENTS. CONTRACTOR SHALL VERIFY AND BE RESPONSIBLE FOR ALL DIMENSIONS AND CONDITIONS ON THE JOB AND THIS OFFICE MUST BE NOTIFIED OF ANY VARIATIONS FROM DIMENSIONS AND CONDITIONS SHOWN BY THESE DRAWINGS.


LEGAL NOTICE: IT IS A VIOLATION OF ARTICLE 145 OF THE NEW YORK STATE EDUCATION LAW FOR ANY PERSON TO ALTER THIS DOCUMENT IN ANY WAY EXCEPT AS PROVIDED IN SECTION 7209 (2), ARTICLE 145, NEW YORK STATE EDUCATION LAW.


© Copyright Divney Tung Schwalbe, LLP 2019 All rights reserved.

IRRIGATION PLAN 3 OF 6



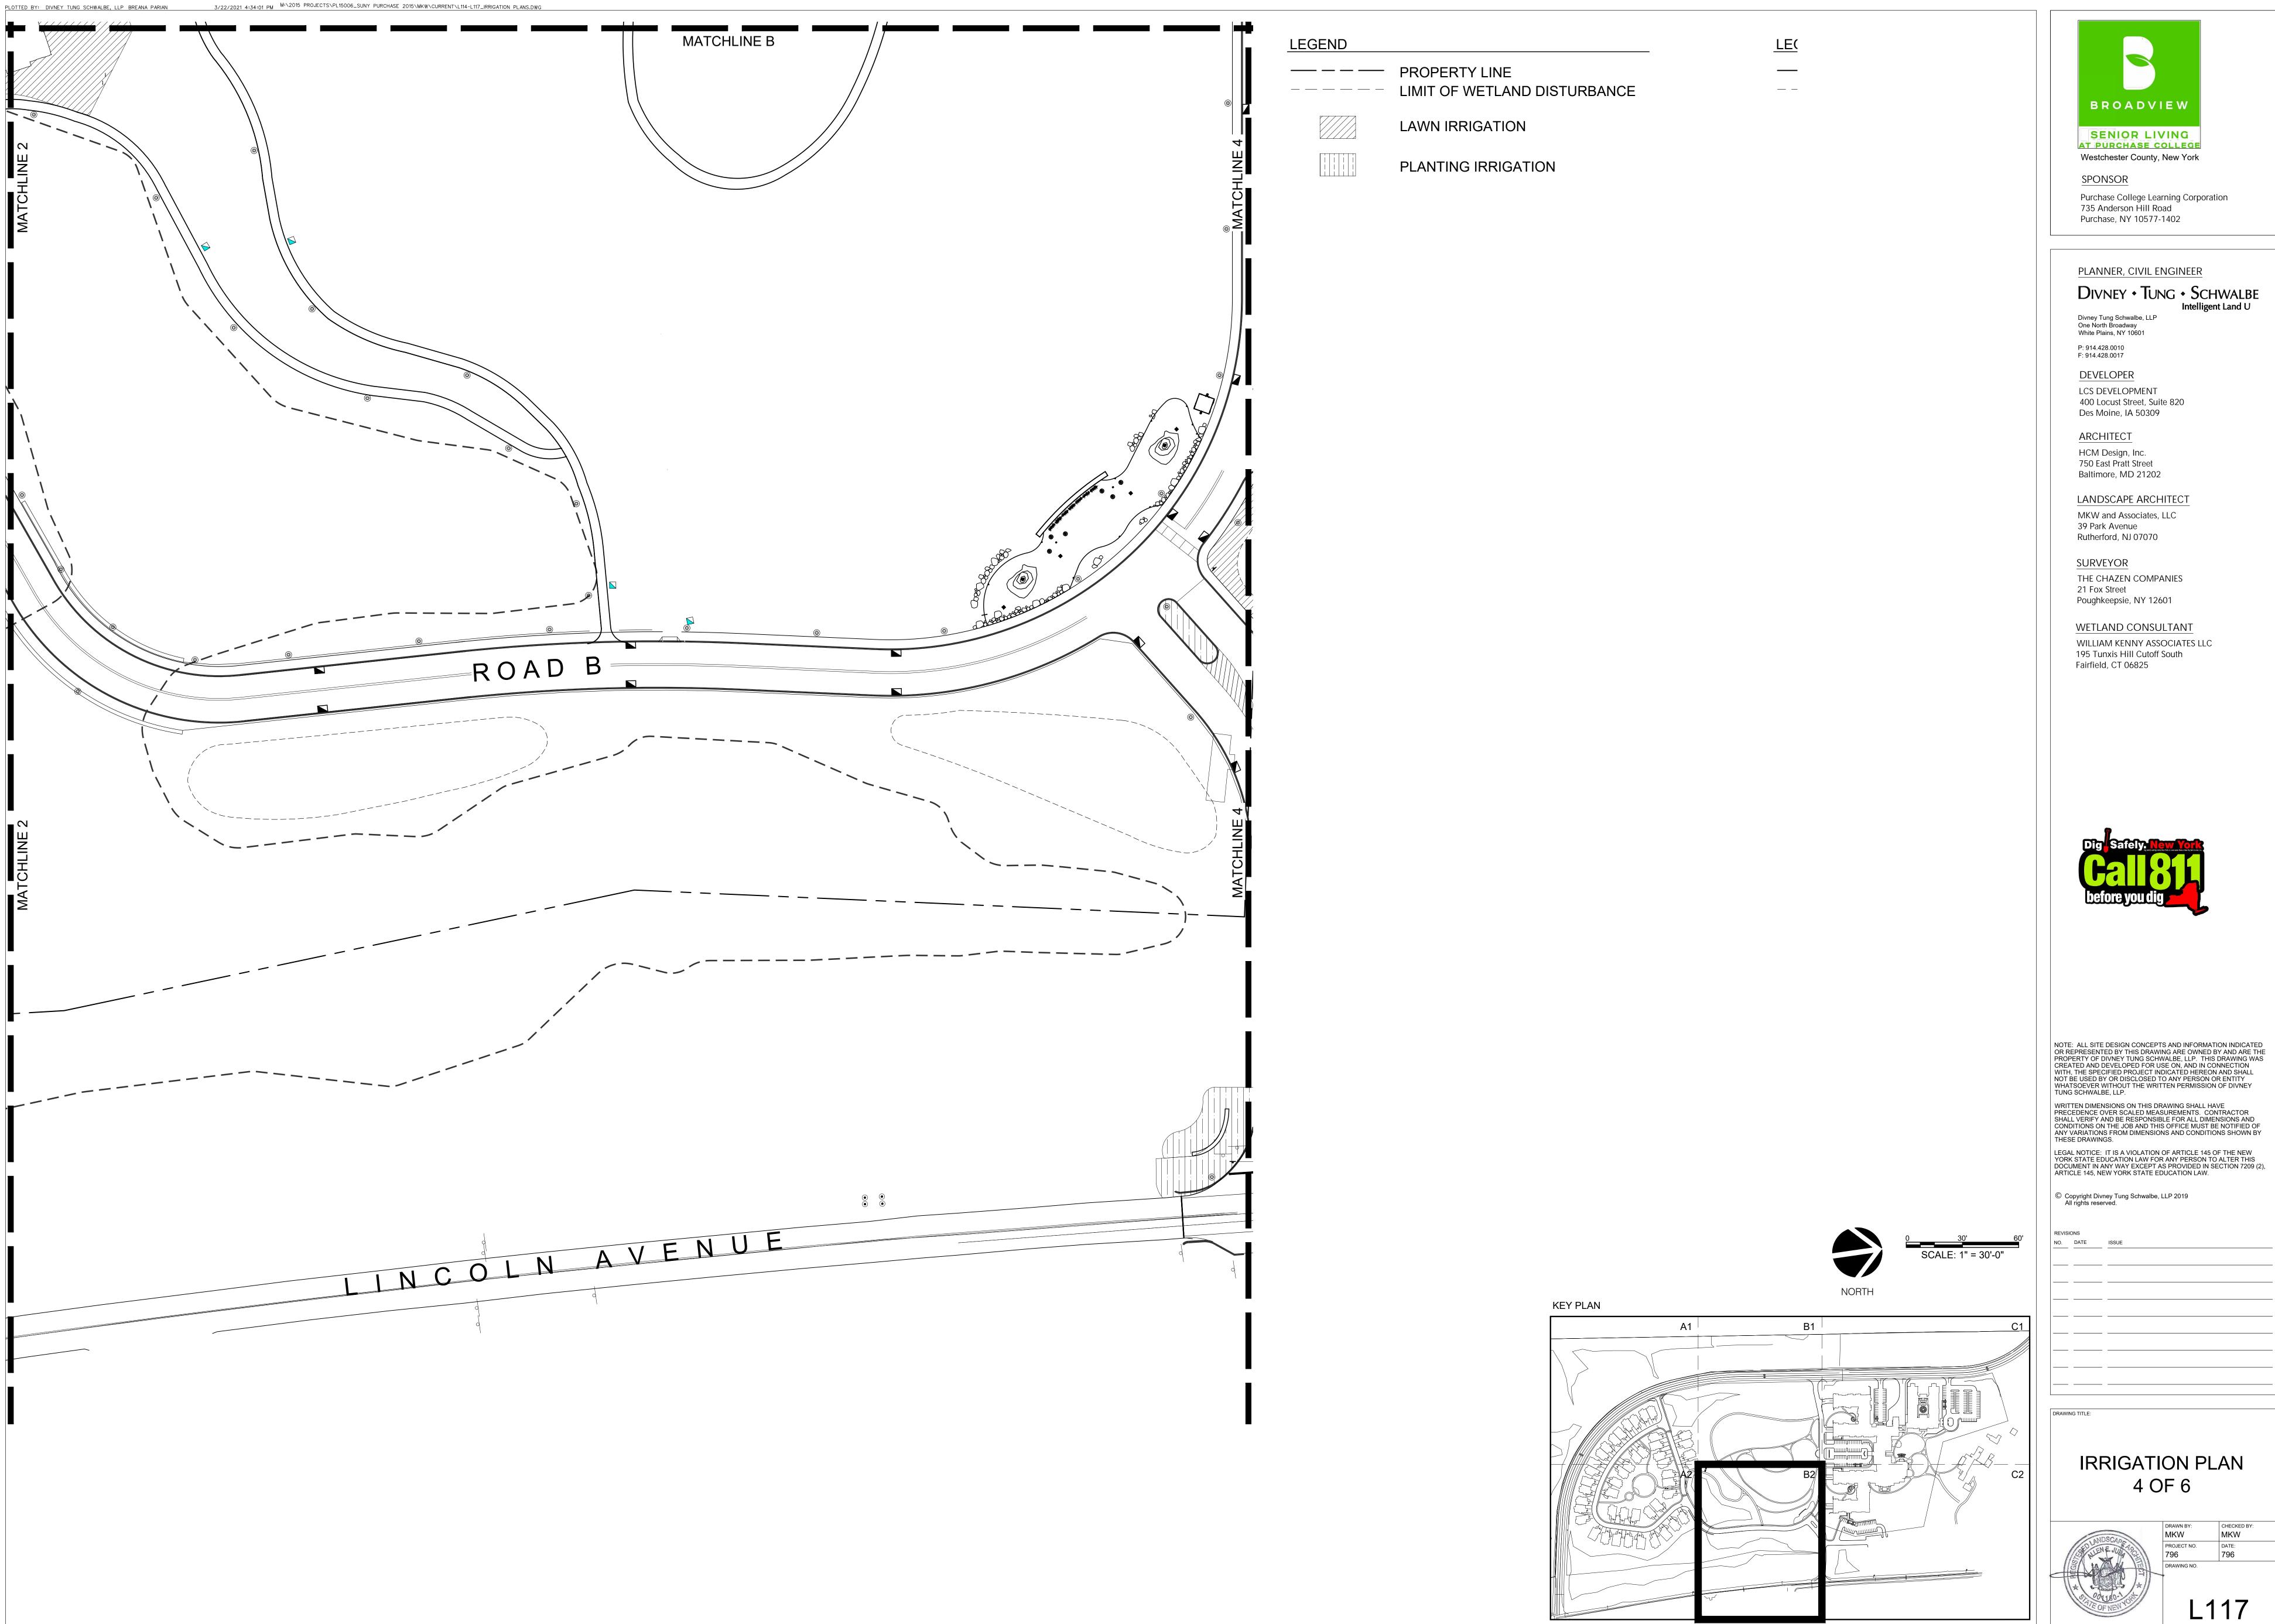

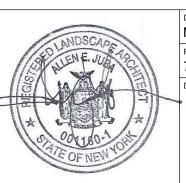

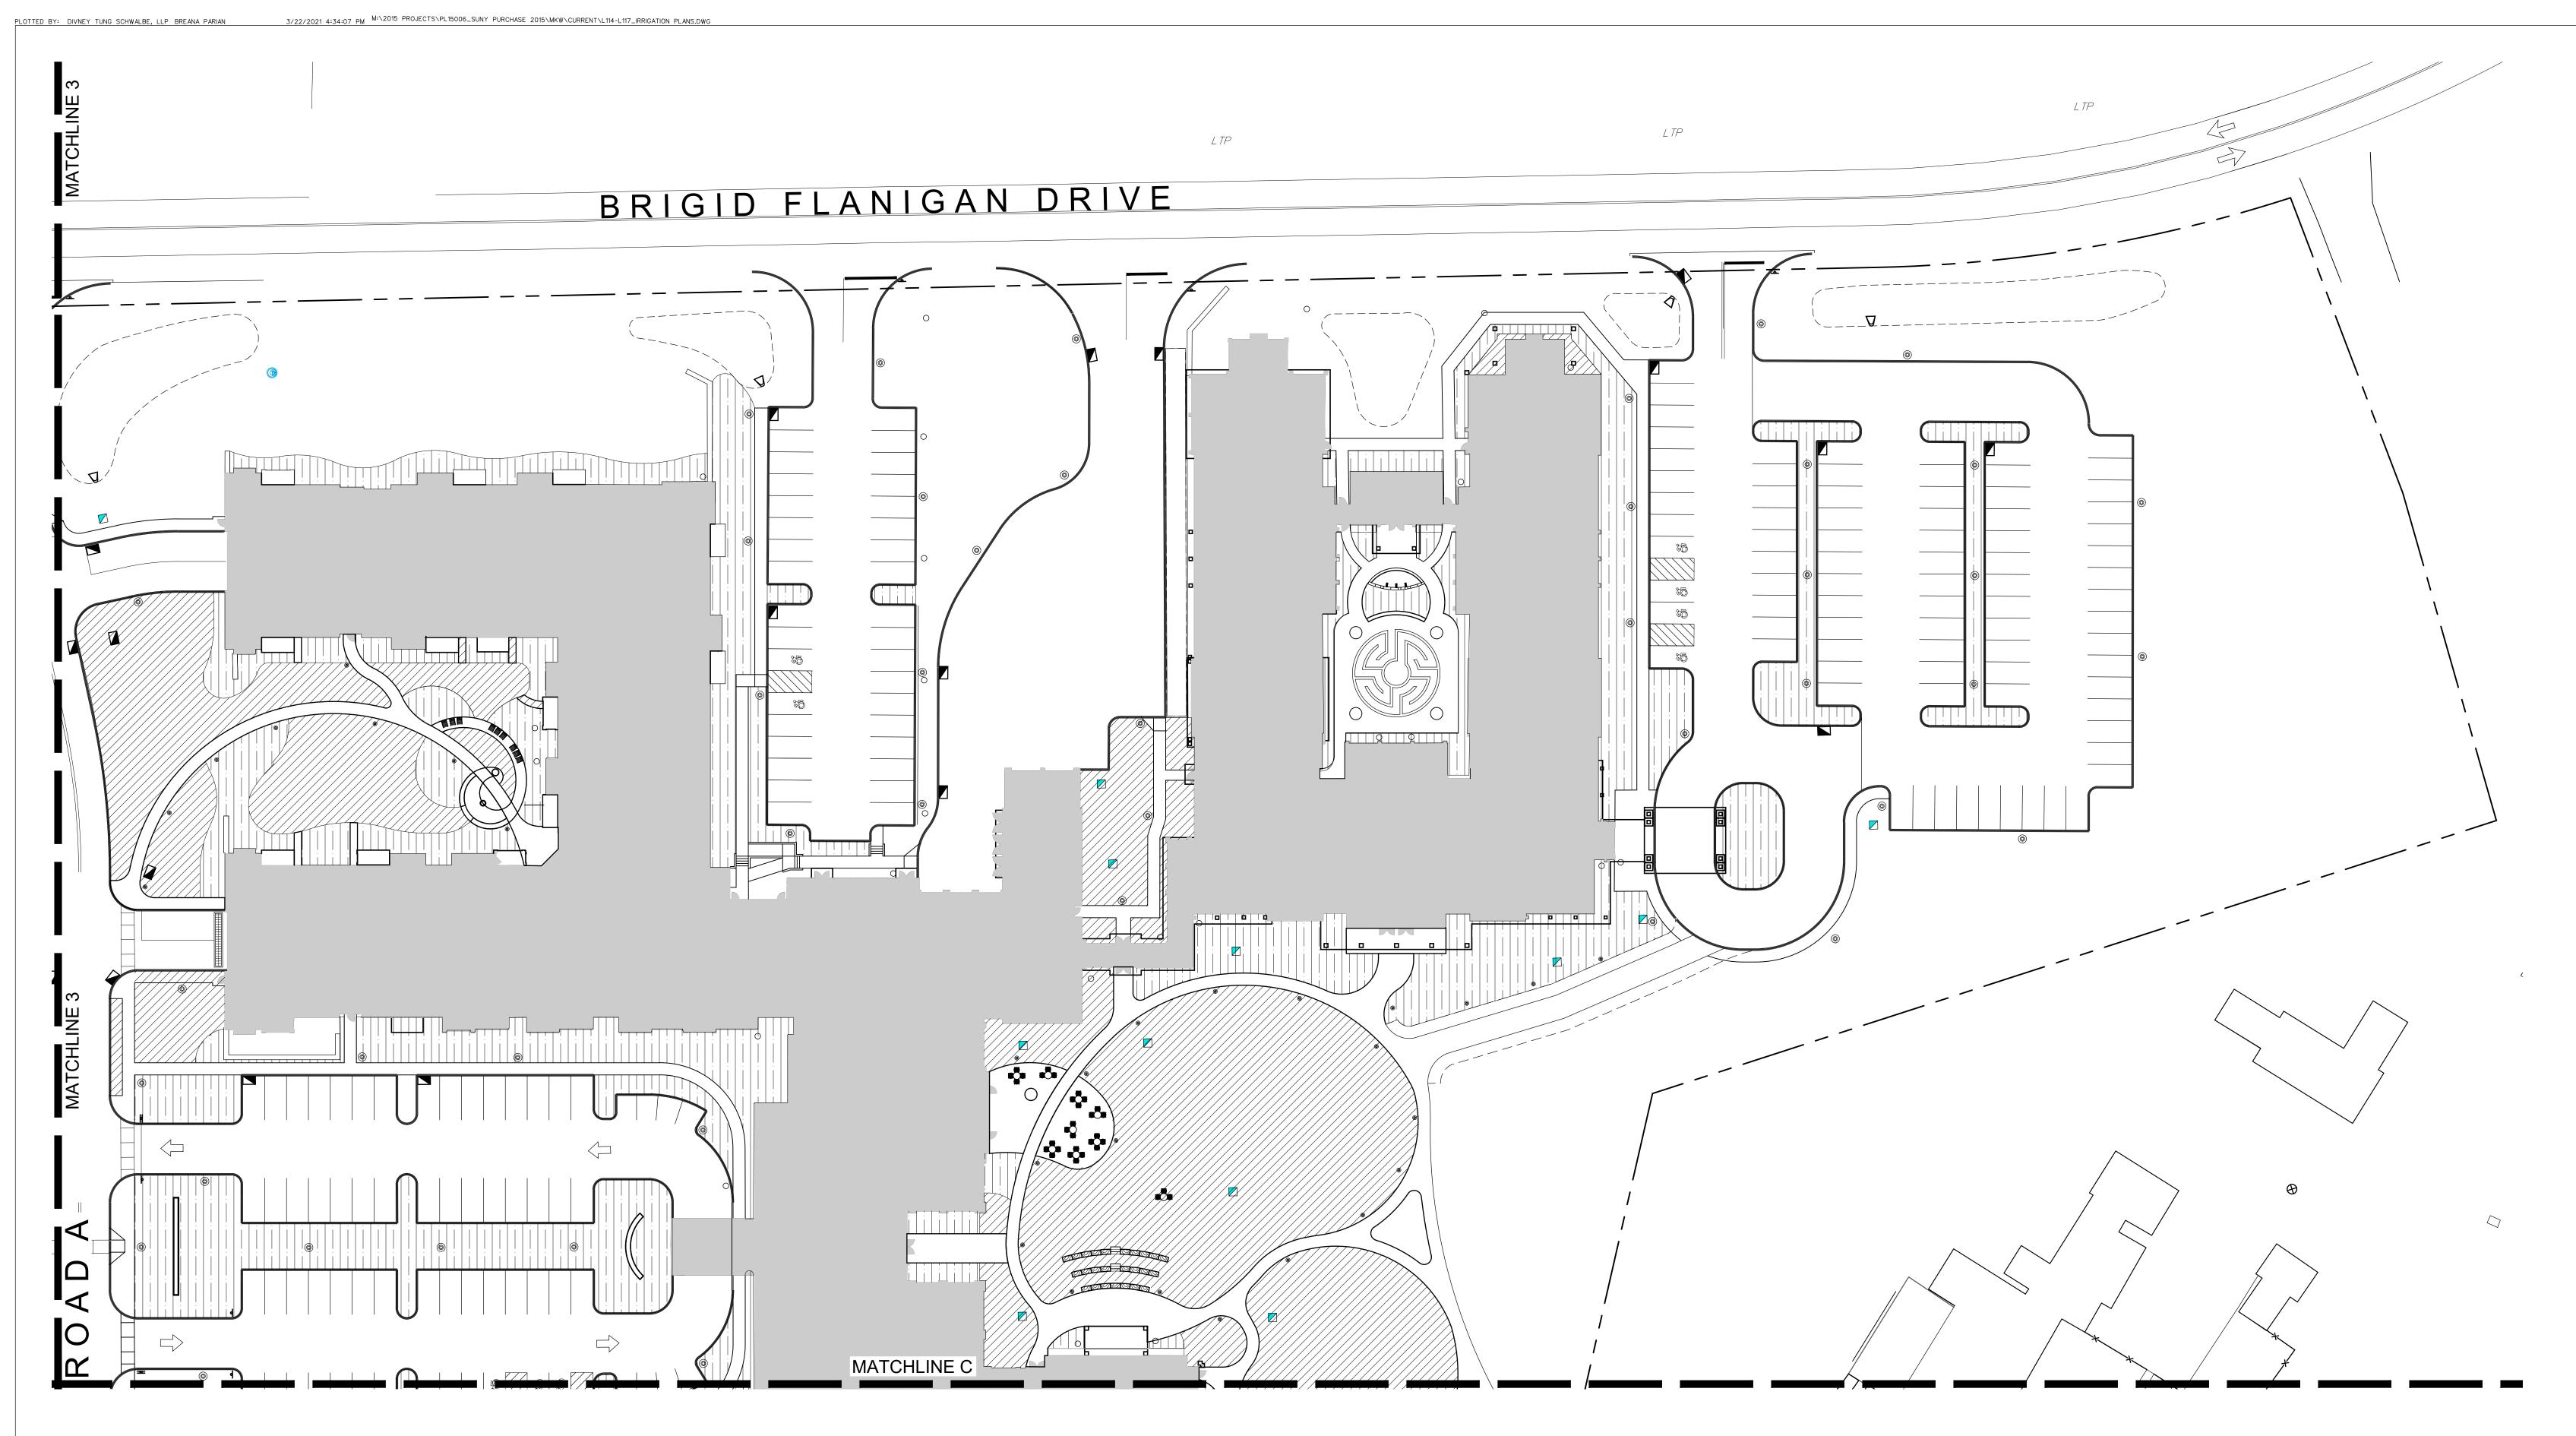

— — — PROPERTY LINE

LIMIT OF WETLAND DISTURBANCE

LAWN IRRIGATION

PLANTING IRRIGATION



KEY PLAN

SCALE: 1" = 30'-0"

IRRIGATION PLAN 5 OF 6

NOTE: ALL SITE DESIGN CONCEPTS AND INFORMATION INDICATED OR REPRESENTED BY THIS DRAWING ARE OWNED BY AND ARE THE PROPERTY OF DIVNEY TUNG SCHWALBE, LLP. THIS DRAWING WAS CREATED AND DEVELOPED FOR USE ON, AND IN CONNECTION WITH, THE SPECIFIED PROJECT INDICATED HEREON AND SHALL NOT BE USED BY OR DISCLOSED TO ANY PERSON OR ENTITY WHATSOEVER WITHOUT THE WRITTEN PERMISSION OF DIVNEY TUNG SCHWALBE, LLP.

WRITTEN DIMENSIONS ON THIS DRAWING SHALL HAVE PRECEDENCE OVER SCALED MEASUREMENTS. CONTRACTOR SHALL VERIFY AND BE RESPONSIBLE FOR ALL DIMENSIONS AND CONDITIONS ON THE JOB AND THIS OFFICE MUST BE NOTIFIED OF ANY VARIATIONS FROM DIMENSIONS AND CONDITIONS SHOWN BY THESE DRAWINGS.

LEGAL NOTICE: IT IS A VIOLATION OF ARTICLE 145 OF THE NEW YORK STATE EDUCATION LAW FOR ANY PERSON TO ALTER THIS DOCUMENT IN ANY WAY EXCEPT AS PROVIDED IN SECTION 7209 (2), ARTICLE 145, NEW YORK STATE EDUCATION LAW.

© Copyright Divney Tung Schwalbe, LLP 2019 All rights reserved.

BROADVIEW

SENIOR LIVING AT PURCHASE COLLEGE

Westchester County, New York

Purchase, NY 10577-1402

PLANNER, CIVIL ENGINEER

Divney Tung Schwalbe, LLP One North Broadway White Plains, NY 10601

P: 914.428.0010 F: 914.428.0017

DEVELOPER

ARCHITECT

39 Park Avenue

SURVEYOR

21 Fox Street

LCS DEVELOPMENT

HCM Design, Inc. 750 East Pratt Street

Baltimore, MD 21202

LANDSCAPE ARCHITECT

MKW and Associates, LLC

THE CHAZEN COMPANIES

WETLAND CONSULTANT

195 Tunxis Hill Cutoff South

Fairfield, CT 06825

WILLIAM KENNY ASSOCIATES LLC

Poughkeepsie, NY 12601

Rutherford, NJ 07070


400 Locust Street, Suite 820 Des Moine, IA 50309

Purchase College Learning Corporation 735 Anderson Hill Road

DIVNEY • TUNG • SCHWALBE

SPONSOR




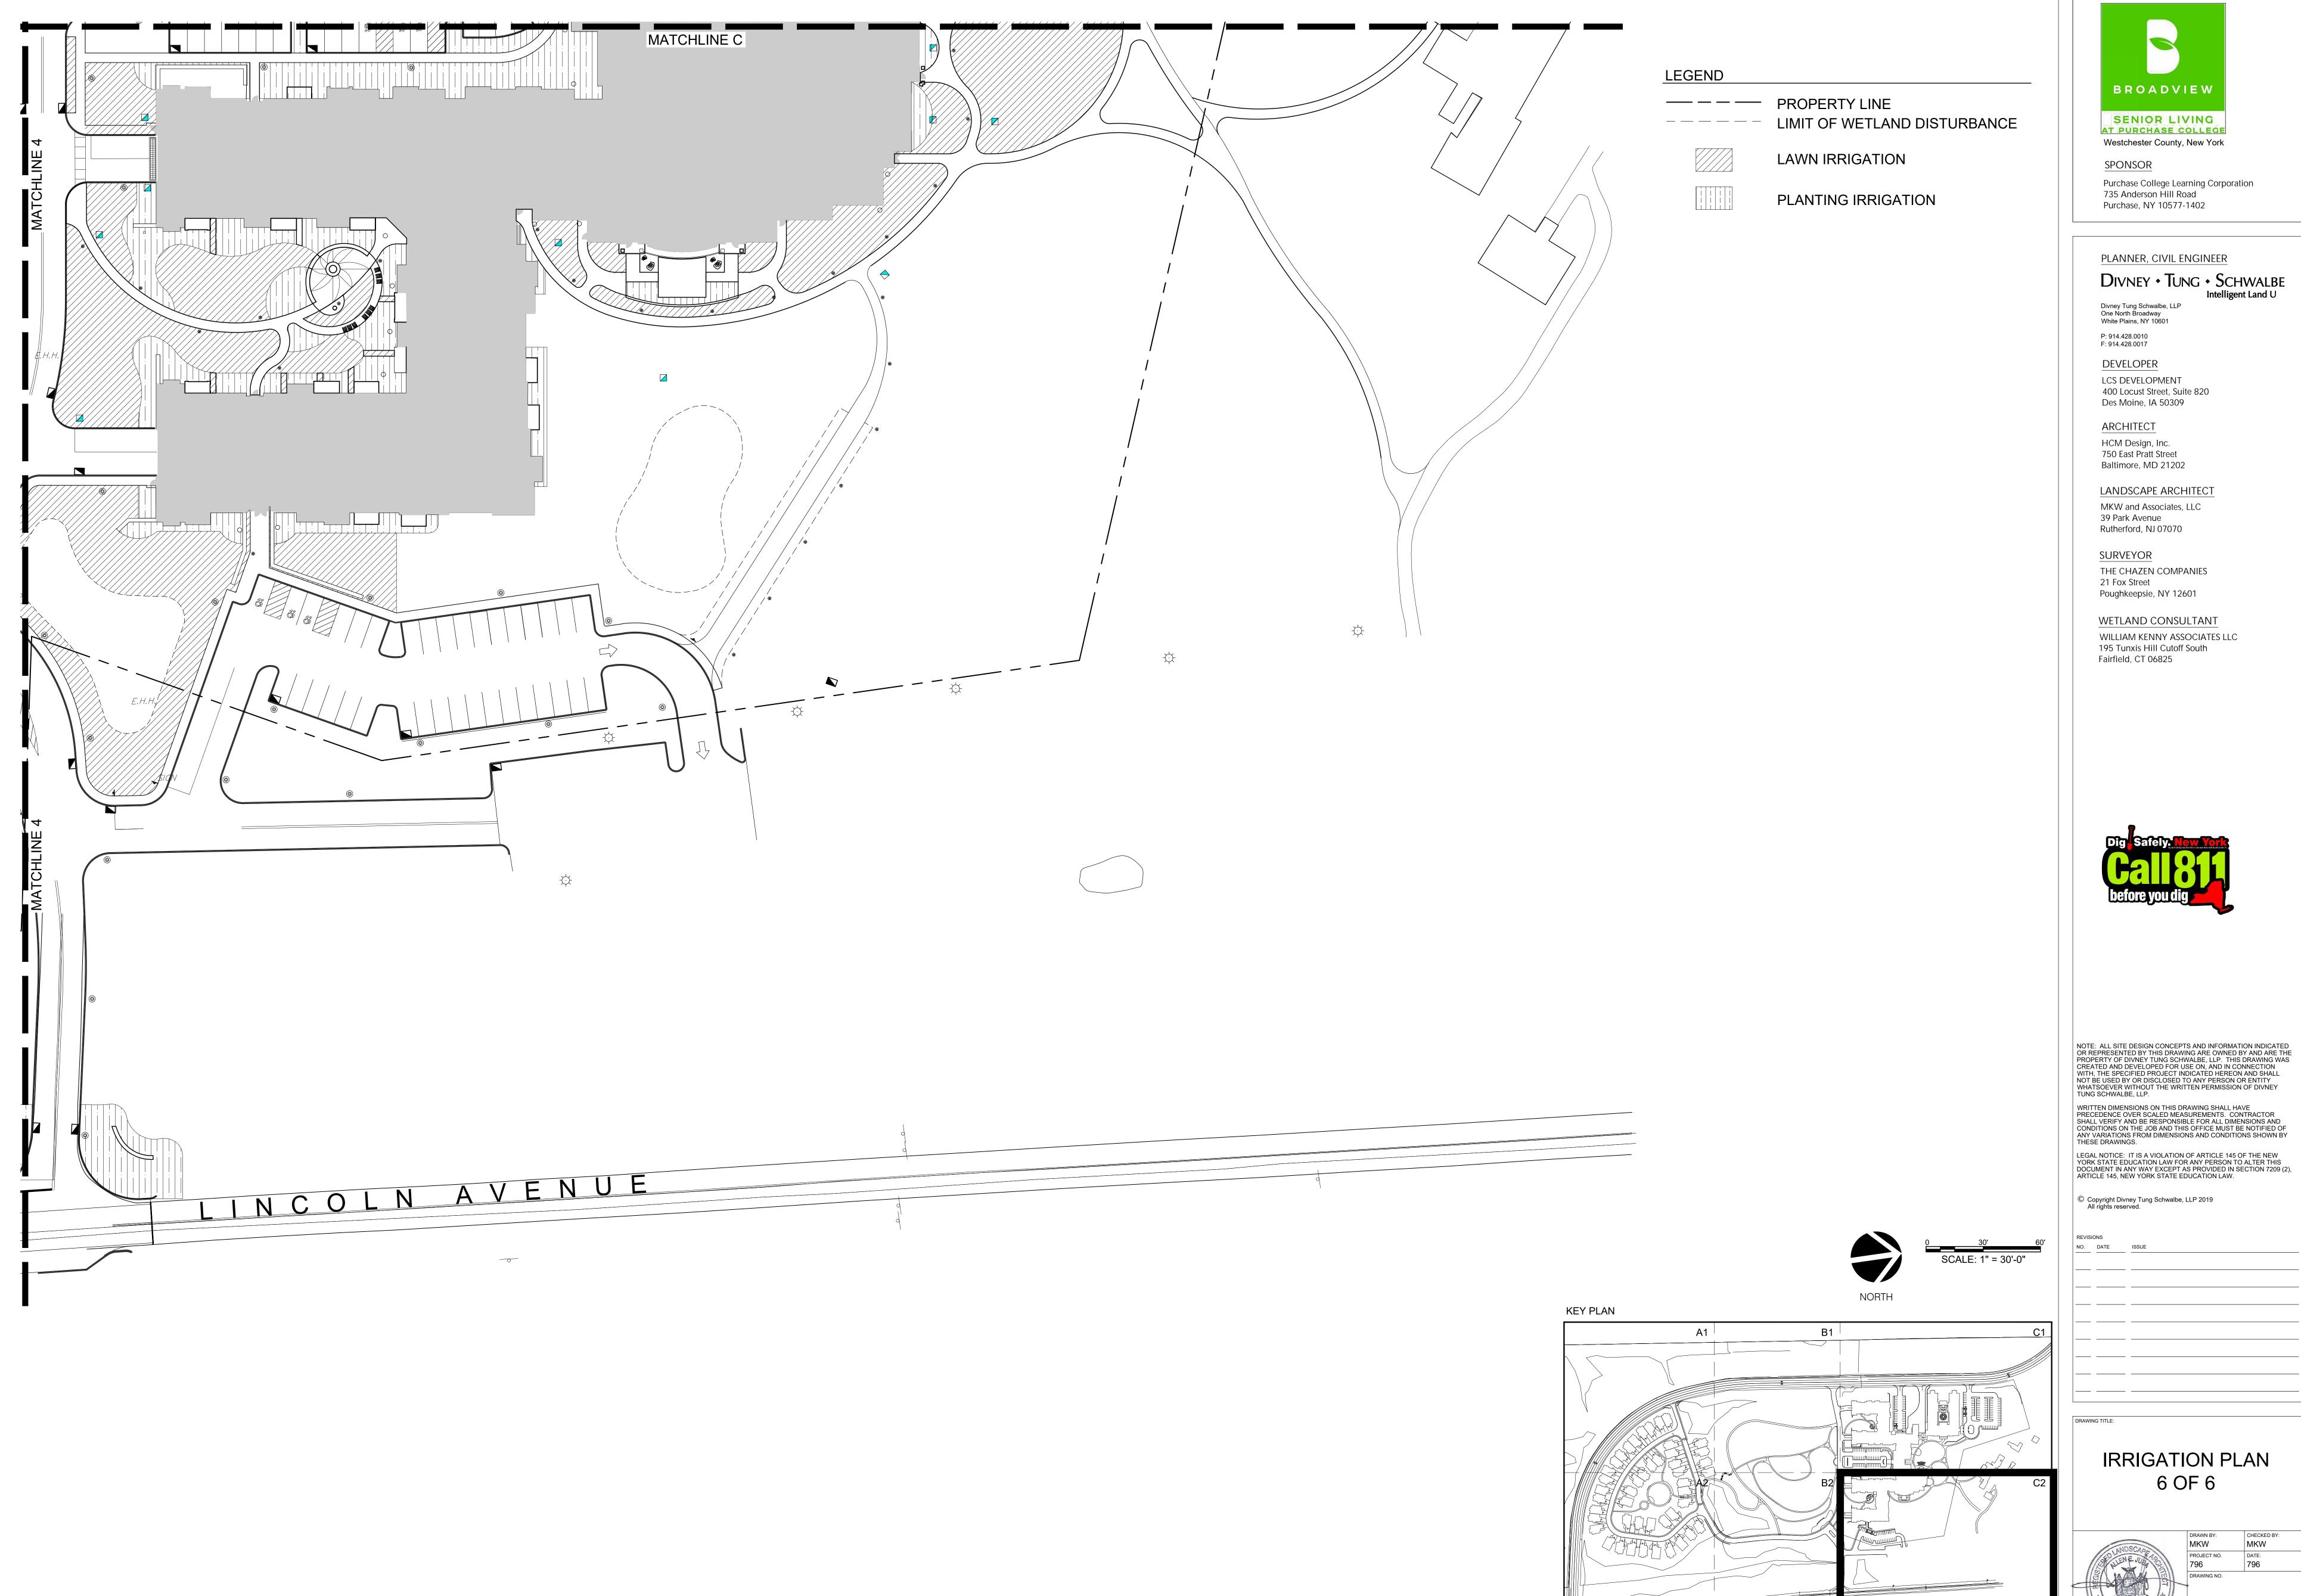


PLOTTED BY: DIVNEY TUNG SCHWALBE, LLP BREANA PARIAN 3/22/2021 4:34:11 PM M:\2015 PROJECTS\PL15006_SUNY PURCHASE 2015\MKW\CURRENT\L114-L117_IRRIGATION PLANS.DWG



SCALE: 1" = 300'

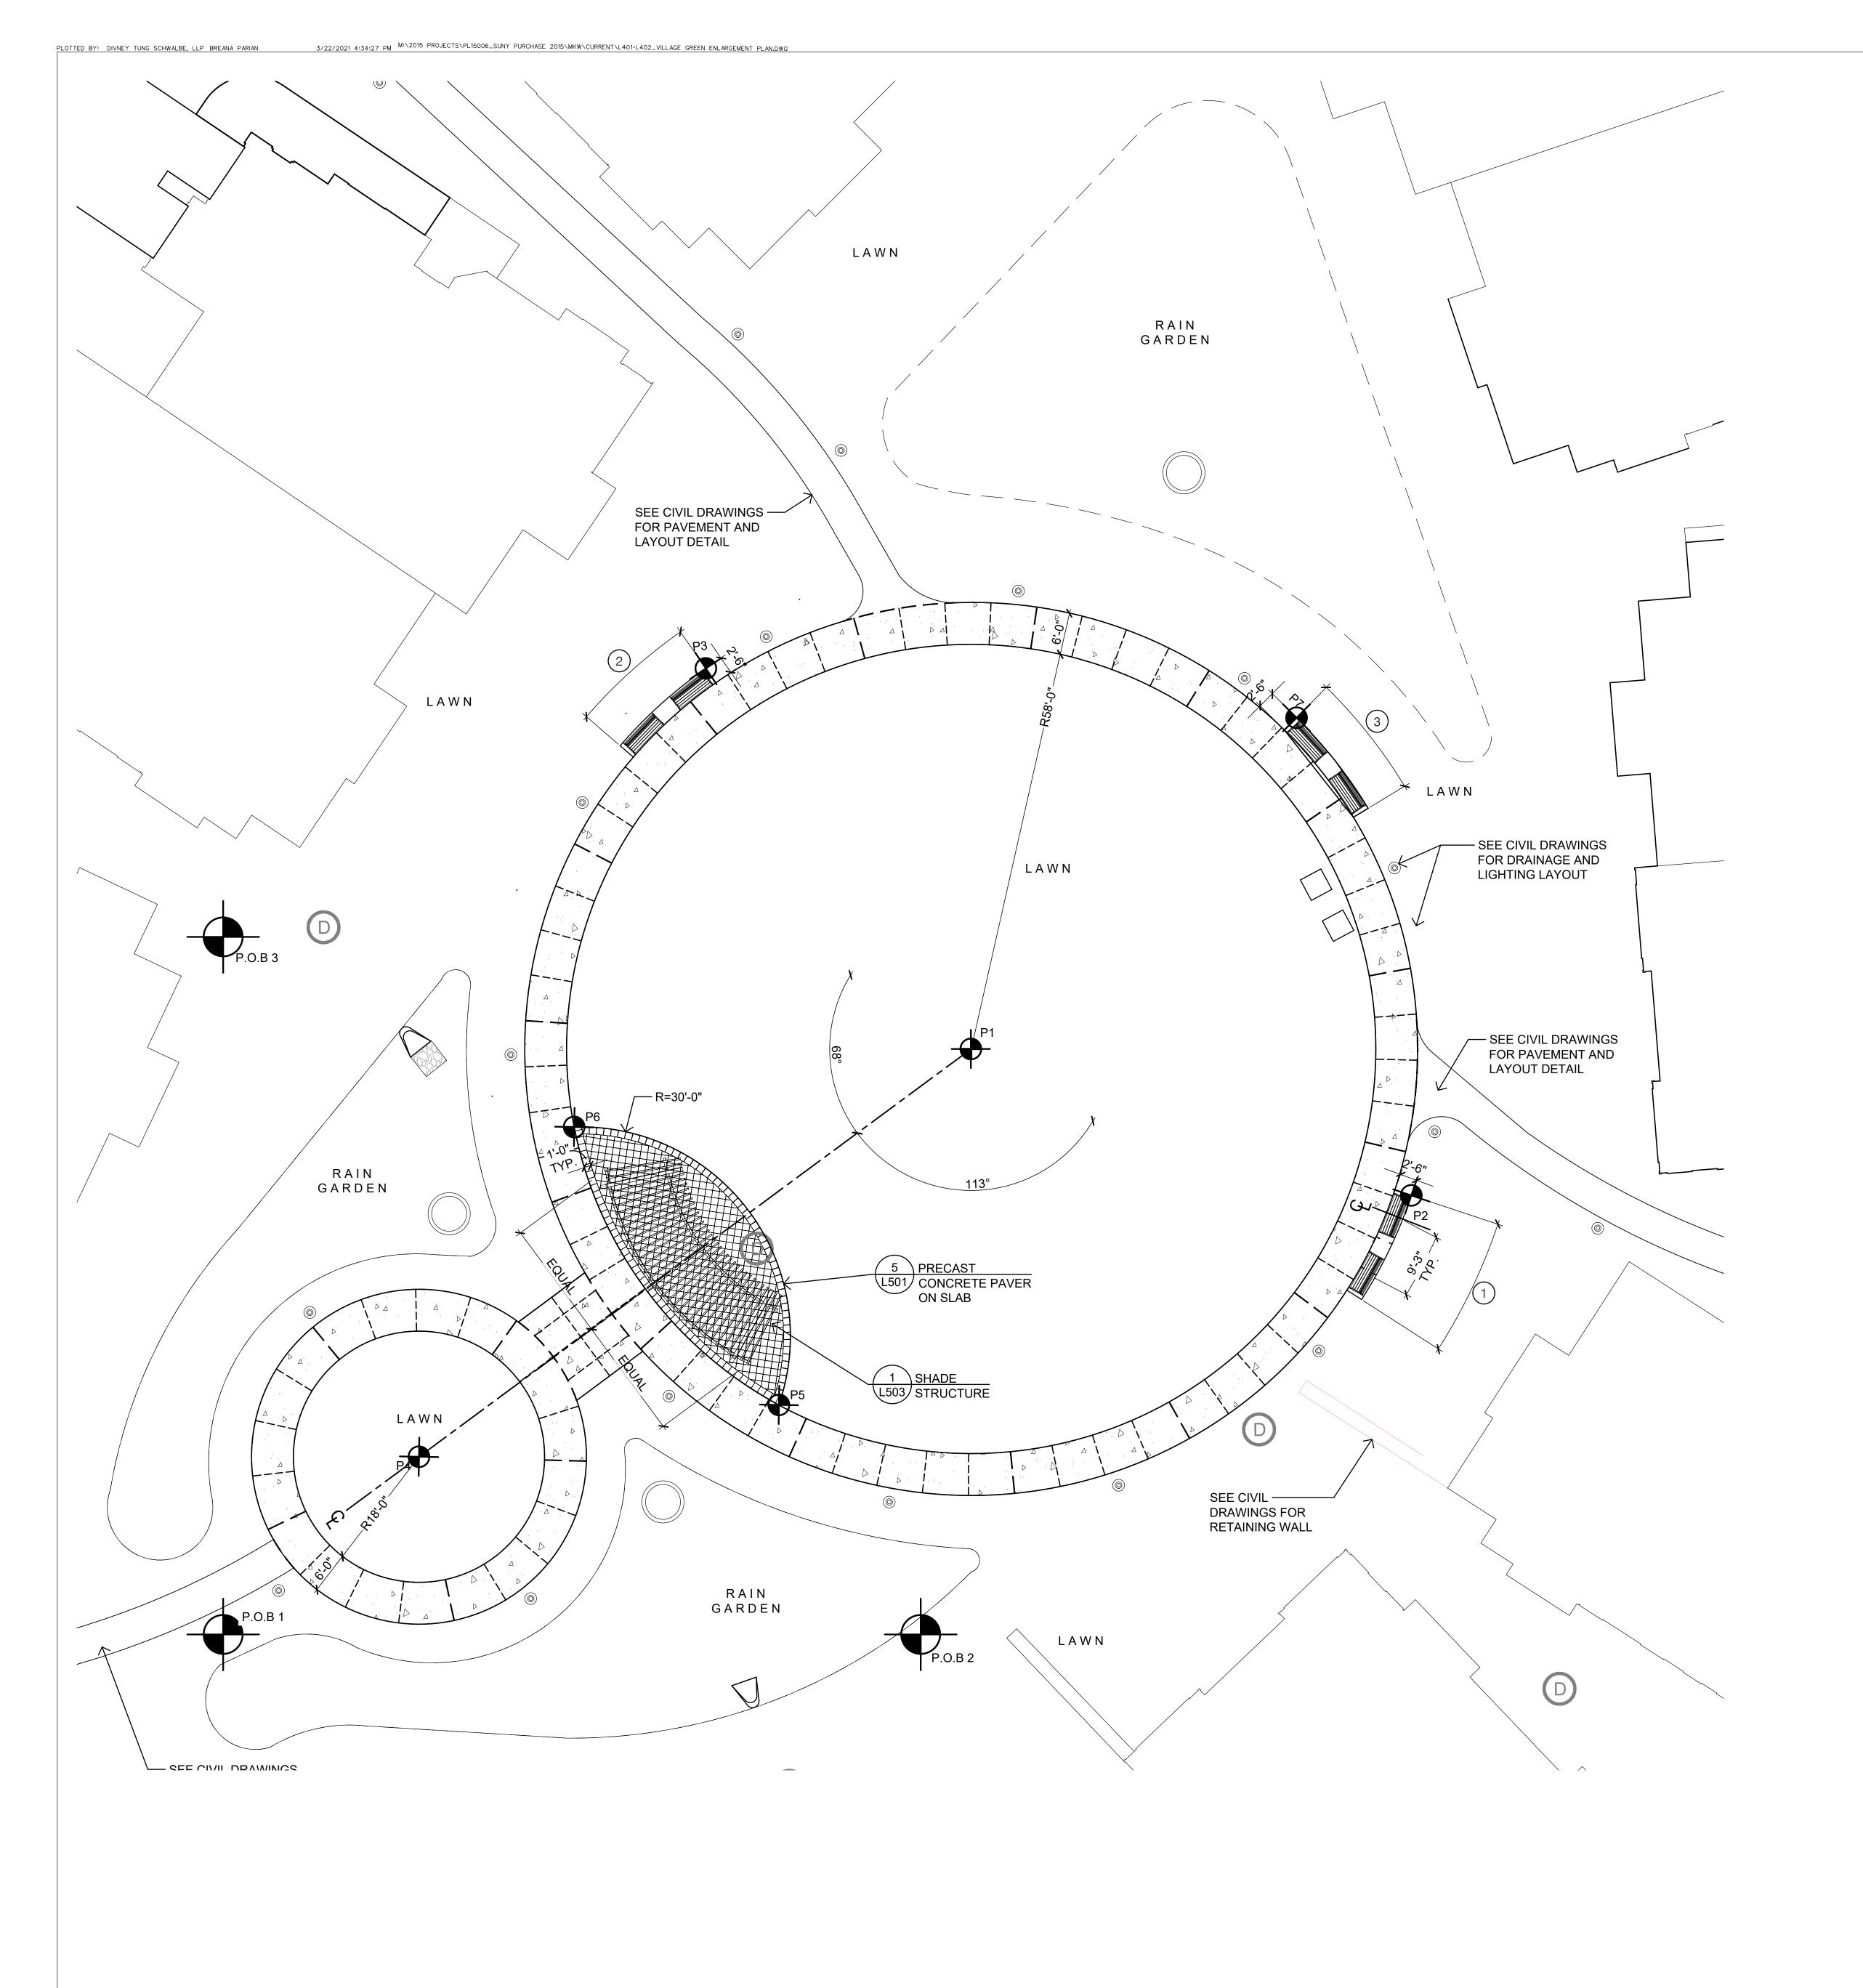



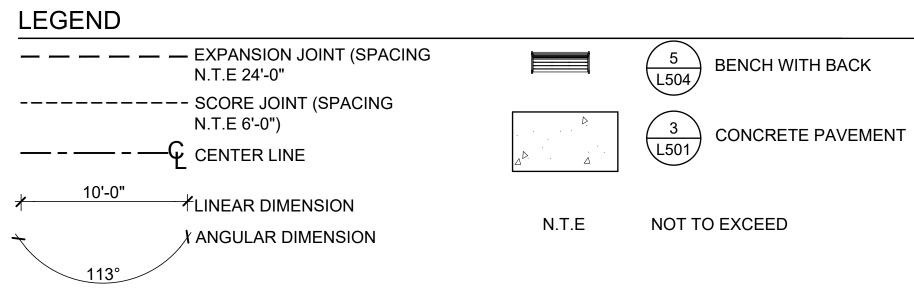

POINT OF BEGINNING (P.O.B)

LOCATION POINT


NOTE: SEE CIVIL DRAWINGS FOR GRADING AND DRAINAGE

	POINT OF	BEGINNING	SURVEY LOCAT	IONS		RADII	SCHEDULE
					ARC	RADIUS	ANGLE
.O.B	X	Y	SURVEY X- COORDINATE	SURVEY Y- COORDINATE	1	66'-6"	23°
1	0	0	9328.82	6835.23	2	66'-6"	23°
Į.	0	0	9320.02	0033.23	3	66'-6"	23°
2	100'-0"	0	9342.98	6934.22			
3	0	100' 0"	0220.83	6840 30		LOCATION P	OINTS 📤

X = HORIZONTAL DISTANCE, Y = VERTICAL DISTANCE


LOCATION POINTS 💠						
POINT	POINT X					
1	1 107'-3"					
2	170'-3"	62'-8"				
3	69'-2"	138'-6"				
4	28'-1"	25'-6"				
5	79'-8"	33'-0"				
6	50'-4"	72'-9"				
7	7 153'-11"					

 X = HORIZONTAL DISTANCE, Y = VERTICAL DISTANCE; TAKEN FROM P.O.B 1



KEY PLAN

A1	B1
	; \\\\\\\\\\\\\\\\\\\\\\\\\\\\\\\\\\\\
A2	B2 C2

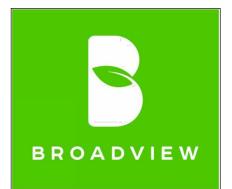

Westchester County, New York

SENIOR LIVING

LENGTH

26'-9"

26'-9"

26'-9"

SPONSOR

Purchase College Learning Corporation 735 Anderson Hill Road Purchase, NY 10577-1402

PLANNER, CIVIL ENGINEER

DIVNEY • TUNG • SCHWALBE

Divney Tung Schwalbe, LLP One North Broadway White Plains, NY 10601

P: 914.428.0010 F: 914.428.0017 DEVELOPER

LCS DEVELOPMENT 400 Locust Street, Suite 820 Des Moine, IA 50309

ARCHITECT HCM Design, Inc. 750 East Pratt Street

Baltimore, MD 21202 LANDSCAPE ARCHITECT

MKW and Associates, LLC 39 Park Avenue Rutherford, NJ 07070

SURVEYOR THE CHAZEN COMPANIES 21 Fox Street Poughkeepsie, NY 12601

WETLAND CONSULTANT WILLIAM KENNY ASSOCIATES LLC 195 Tunxis Hill Cutoff South Fairfield, CT 06825



NOTE: ALL SITE DESIGN CONCEPTS AND INFORMATION INDICATED OR REPRESENTED BY THIS DRAWING ARE OWNED BY AND ARE THE PROPERTY OF DIVNEY TUNG SCHWALBE, LLP. THIS DRAWING WAS CREATED AND DEVELOPED FOR USE ON, AND IN CONNECTION WITH, THE SPECIFIED PROJECT INDICATED HEREON AND SHALL NOT BE USED BY OR DISCLOSED TO ANY PERSON OR ENTITY WHATSOEVER WITHOUT THE WRITTEN PERMISSION OF DIVNEY TUNG SCHWALBE, LLP.

WRITTEN DIMENSIONS ON THIS DRAWING SHALL HAVE PRECEDENCE OVER SCALED MEASUREMENTS. CONTRACTOR SHALL VERIFY AND BE RESPONSIBLE FOR ALL DIMENSIONS AND CONDITIONS ON THE JOB AND THIS OFFICE MUST BE NOTIFIED OF

ANY VARIATIONS FROM DIMENSIONS AND CONDITIONS SHOWN BY THESE DRAWINGS. LEGAL NOTICE: IT IS A VIOLATION OF ARTICLE 145 OF THE NEW YORK STATE EDUCATION LAW FOR ANY PERSON TO ALTER THIS DOCUMENT IN ANY WAY EXCEPT AS PROVIDED IN SECTION 7209 (2), ARTICLE 145, NEW YORK STATE EDUCATION LAW.


© Copyright Divney Tung Schwalbe, LLP 2019 All rights reserved.


KEVIS	SIUNS					
NO.	DATE	ISSUE				
		_				
	-	- -				
		_				

SCALE: 1" = 300'

VILLAGE GREEN LAYOUT & MATERIALS **ENLARGEMENT PLAN**



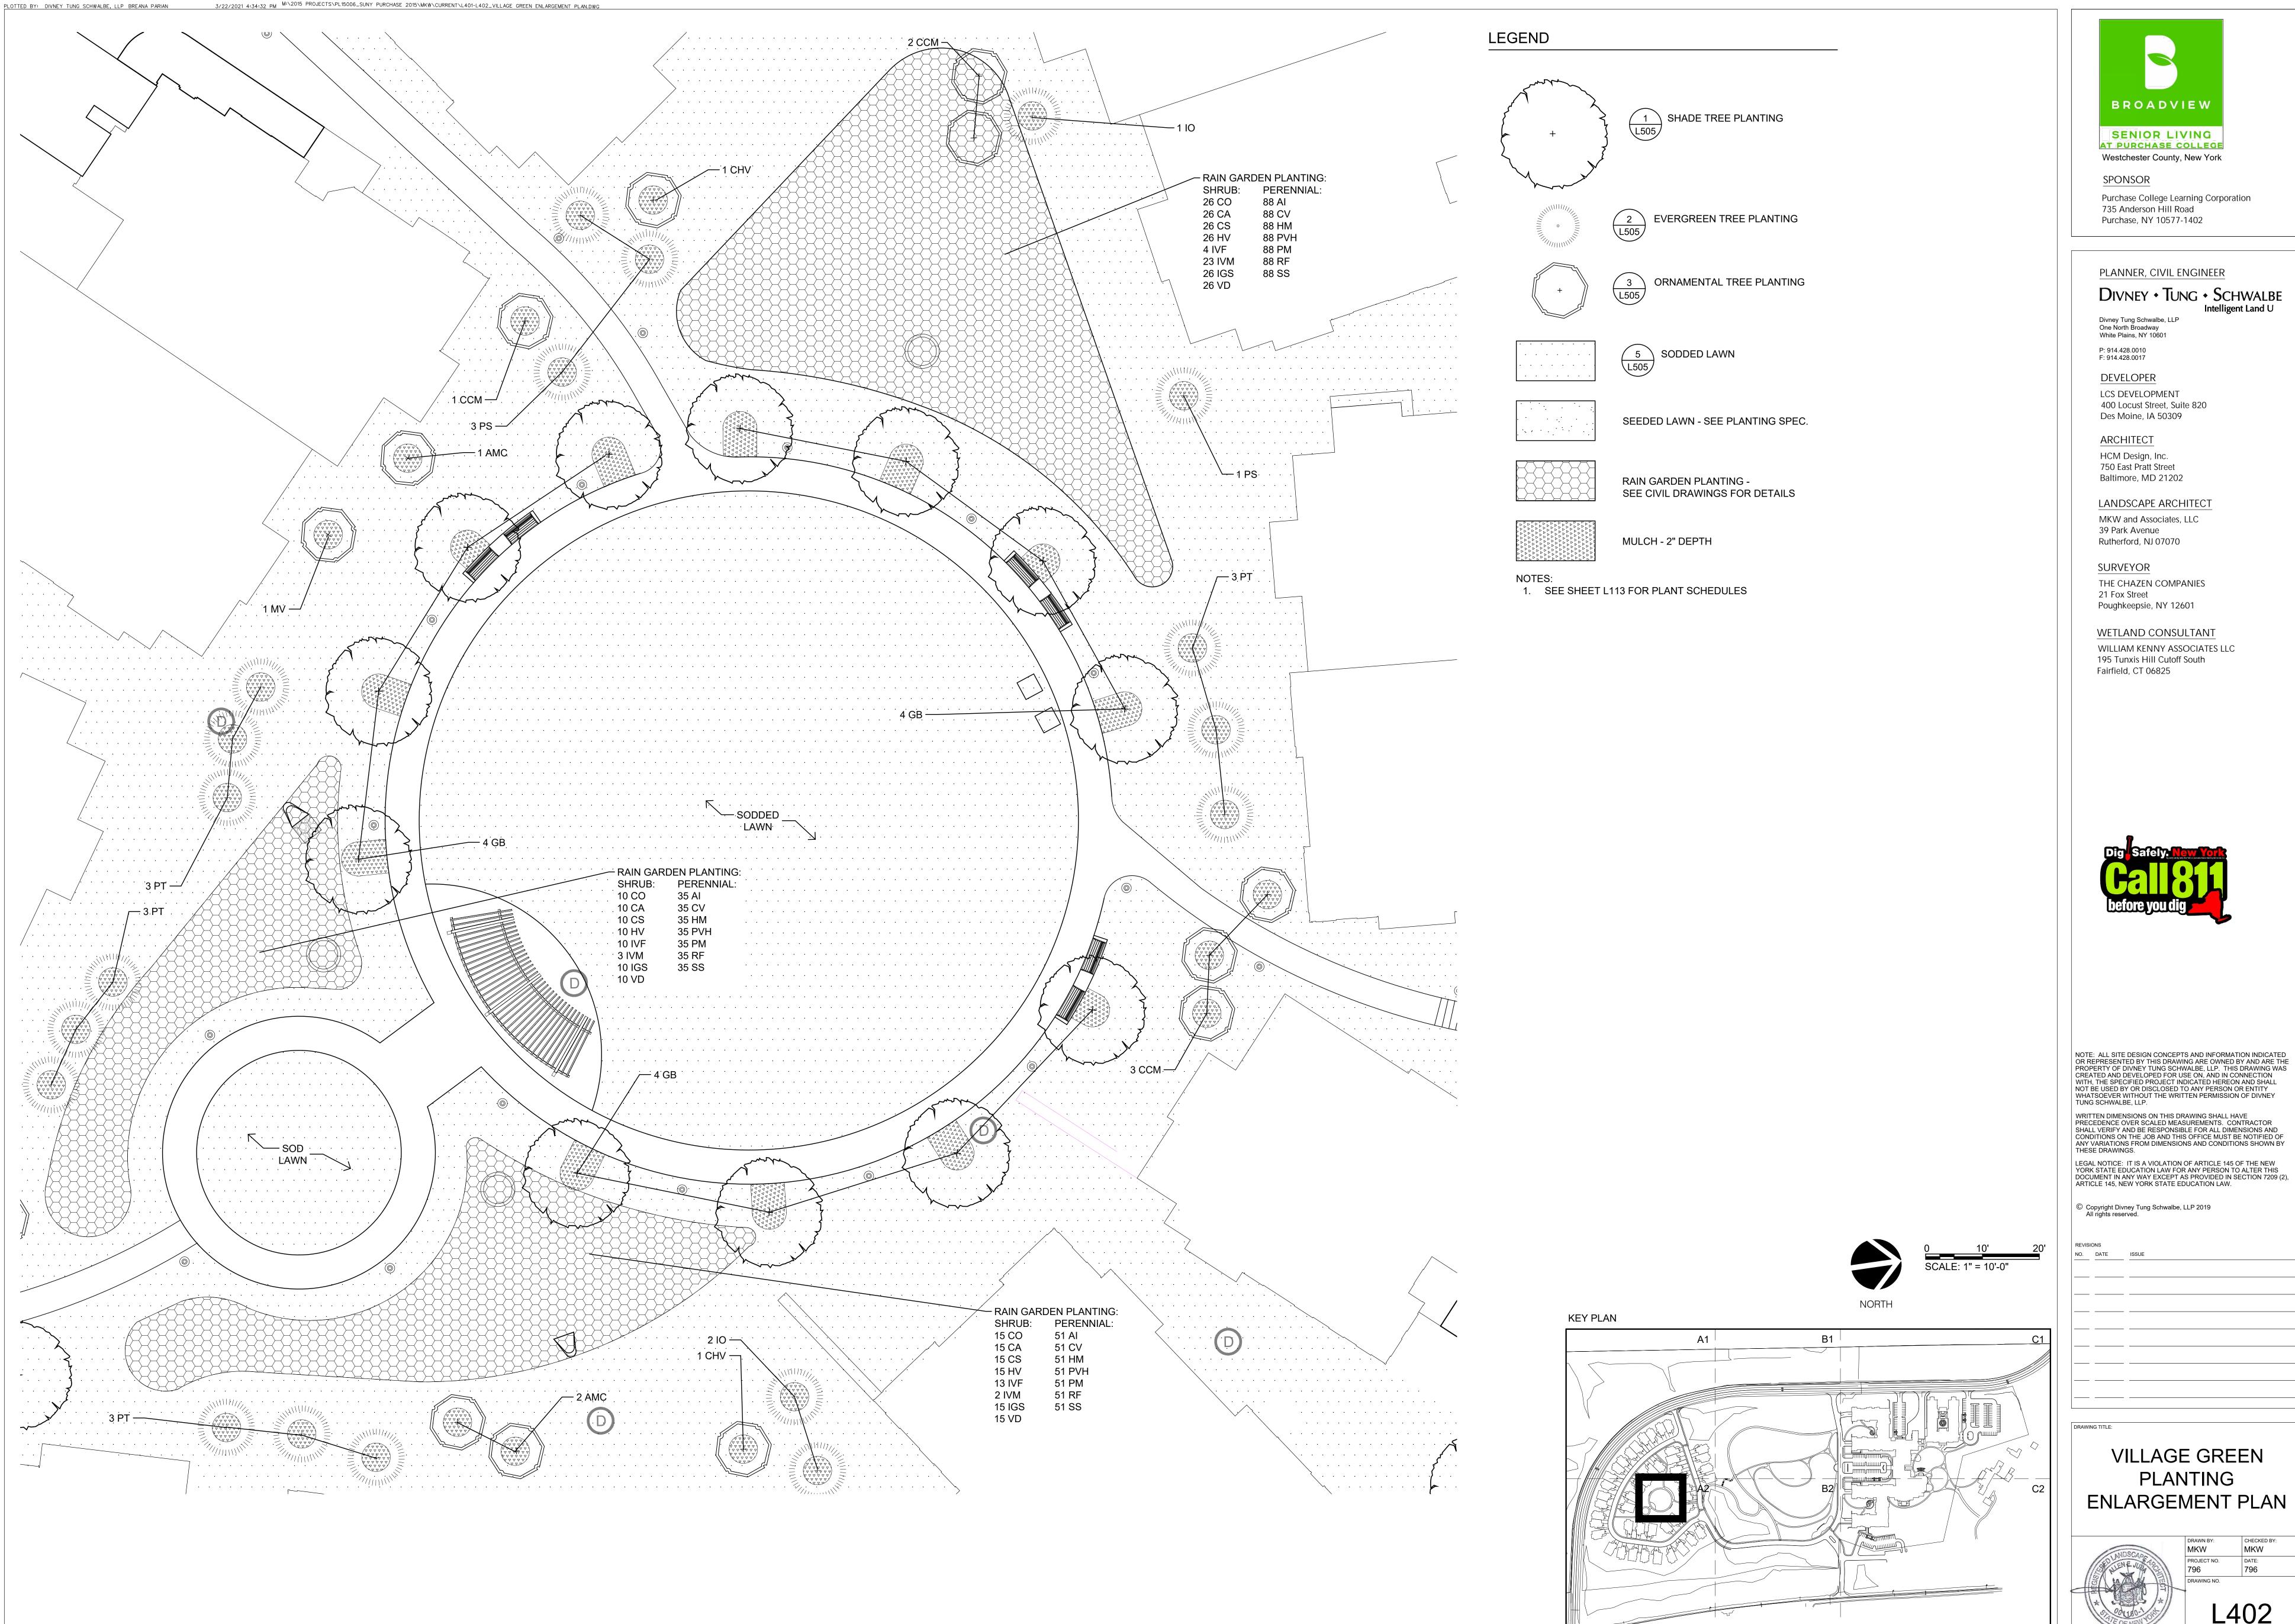

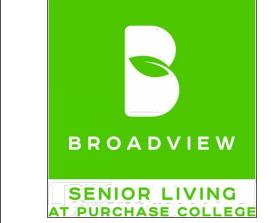

Purchase College Learning Corporation 735 Anderson Hill Road Purchase, NY 10577-1402

PLANNER, CIVIL ENGINEER

DIVNEY • TUNG • SCHWALBE

LCS DEVELOPMENT 400 Locust Street, Suite 820

HCM Design, Inc. 750 East Pratt Street

LANDSCAPE ARCHITECT MKW and Associates, LLC

THE CHAZEN COMPANIES Poughkeepsie, NY 12601

WETLAND CONSULTANT

WILLIAM KENNY ASSOCIATES LLC 195 Tunxis Hill Cutoff South Fairfield, CT 06825



NOTE: ALL SITE DESIGN CONCEPTS AND INFORMATION INDICATED OR REPRESENTED BY THIS DRAWING ARE OWNED BY AND ARE THE PROPERTY OF DIVNEY TUNG SCHWALBE, LLP. THIS DRAWING WAS CREATED AND DEVELOPED FOR USE ON, AND IN CONNECTION WITH, THE SPECIFIED PROJECT INDICATED HEREON AND SHALL WHATSOEVER WITHOUT THE WRITTEN PERMISSION OF DIVNEY


WRITTEN DIMENSIONS ON THIS DRAWING SHALL HAVE PRECEDENCE OVER SCALED MEASUREMENTS. CONTRACTOR SHALL VERIFY AND BE RESPONSIBLE FOR ALL DIMENSIONS AND CONDITIONS ON THE JOB AND THIS OFFICE MUST BE NOTIFIED OF ANY VARIATIONS FROM DIMENSIONS AND CONDITIONS SHOWN BY

ARTICLE 145, NEW YORK STATE EDUCATION LAW.

REVIS	SIONS		
NO	DATE	ISSUE	

VILLAGE GREEN



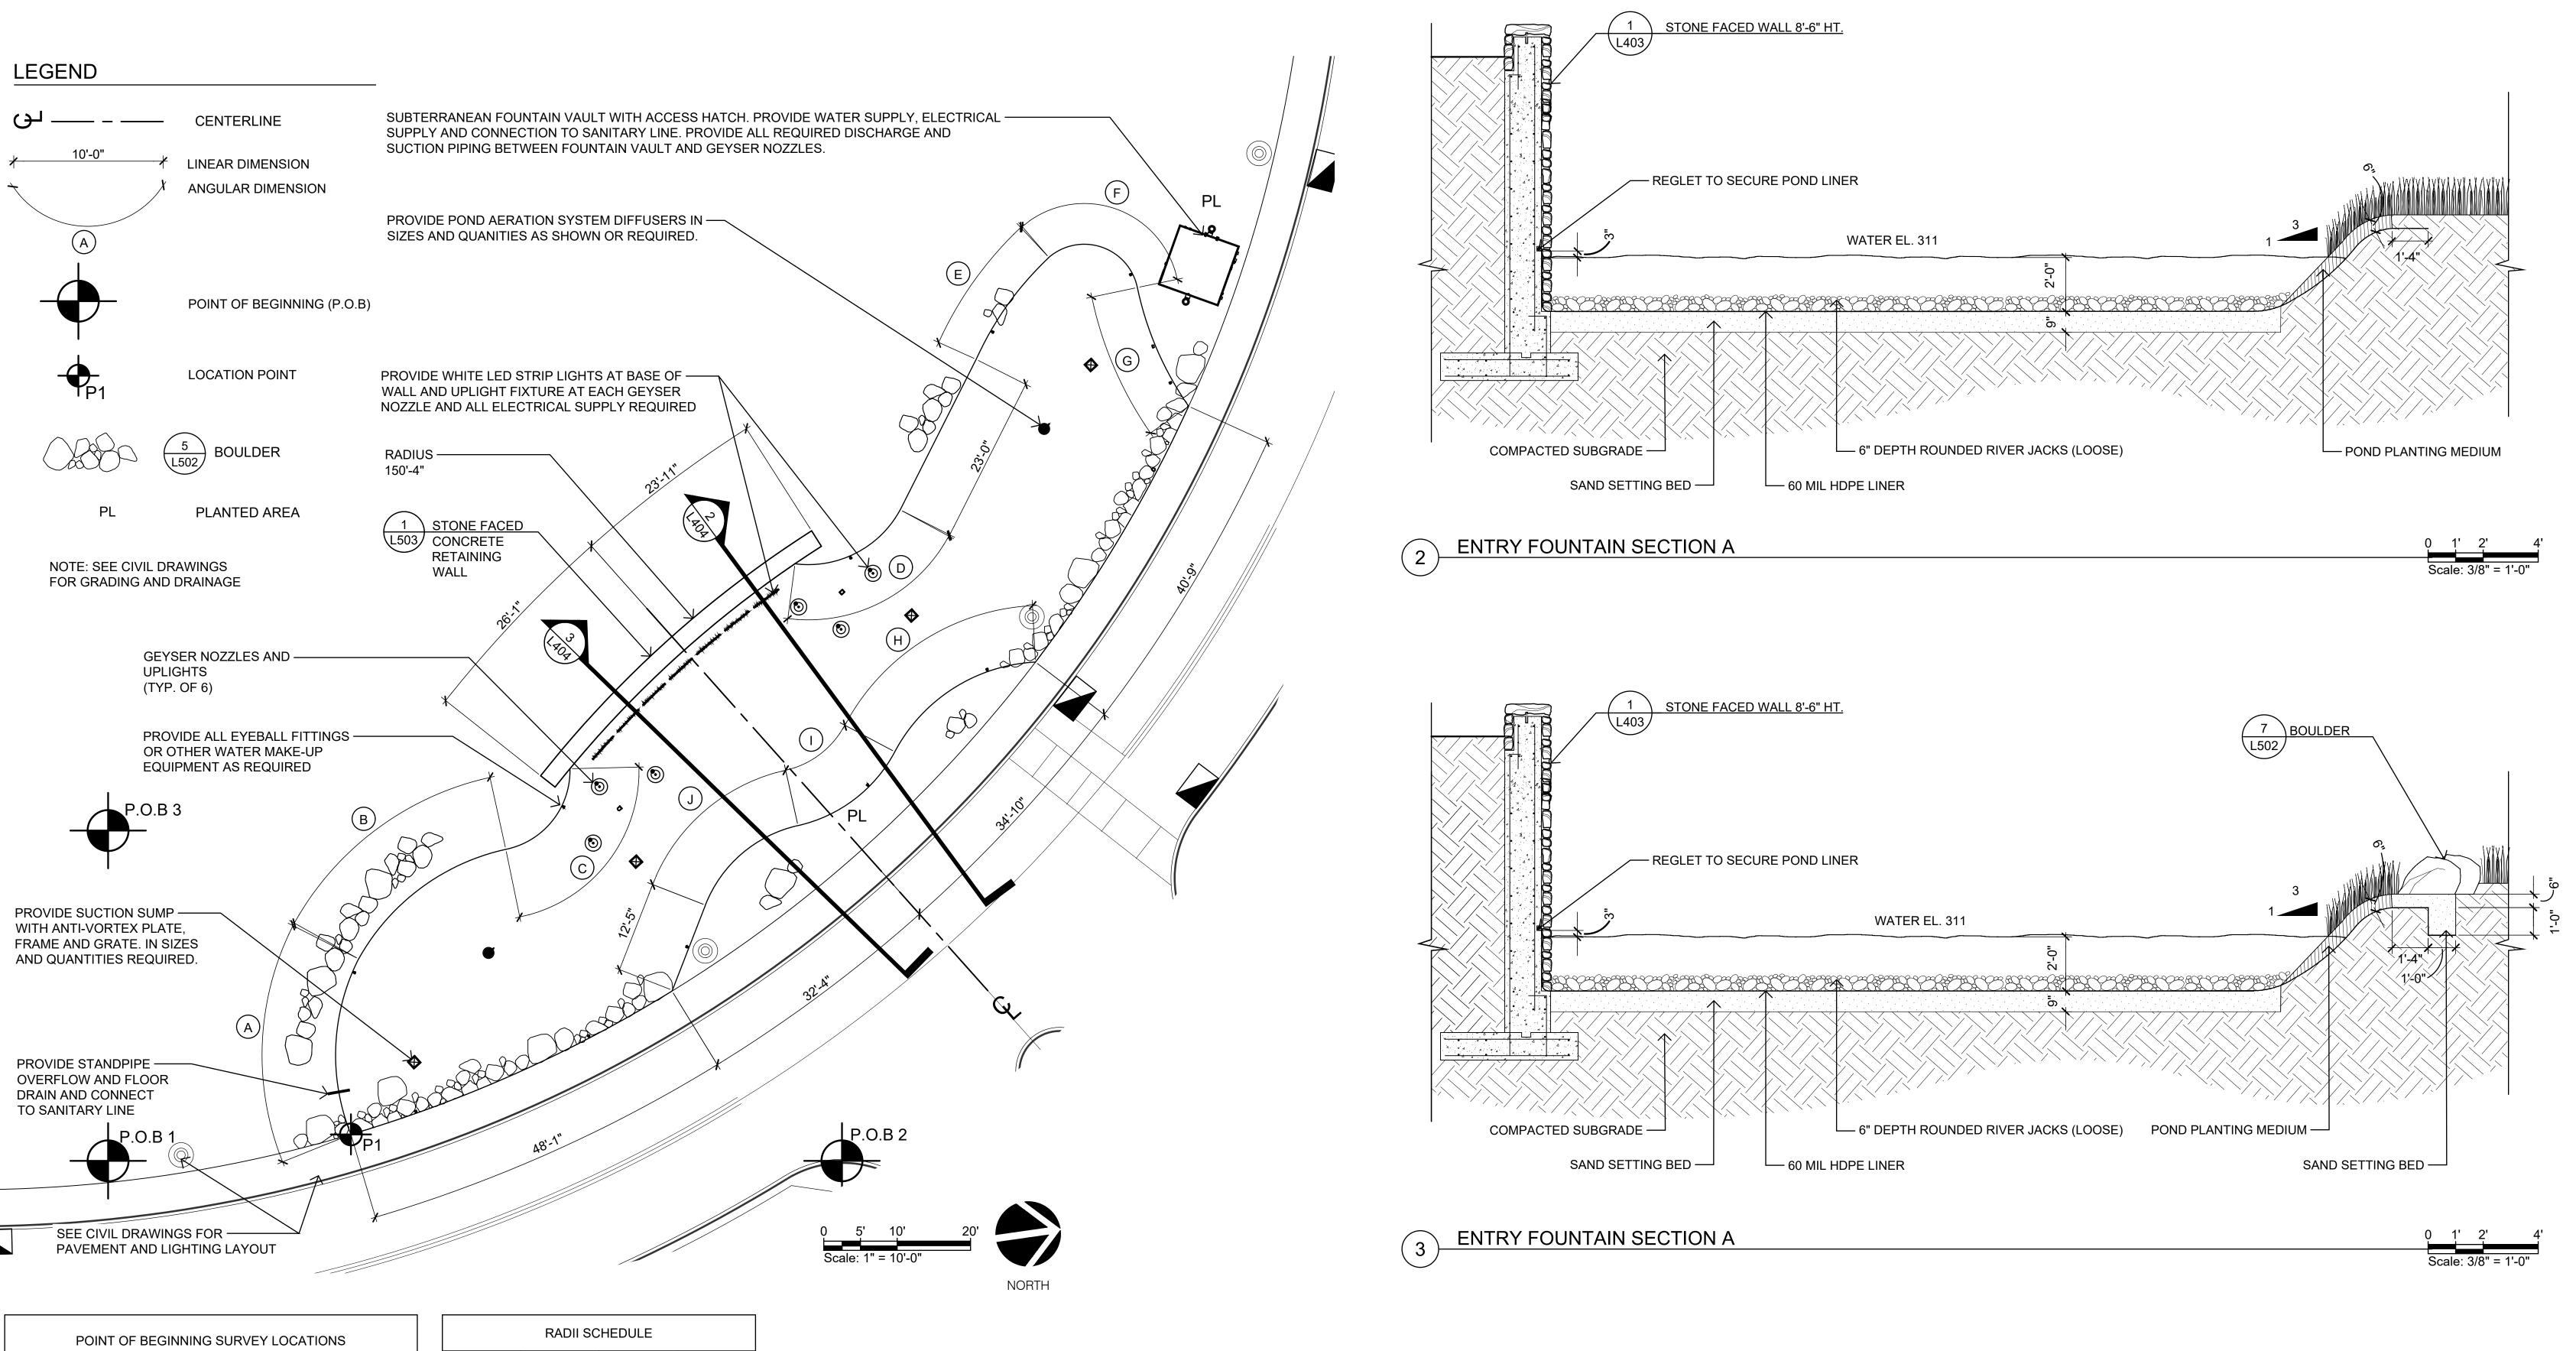

POINT OF BEGINNING SURVEY LOCATIONS						
P.O.B.	X	Y	SURVEY X- COORDINATE	SURVEY Y- COORDINATE		
1	0	0	9576.23	7683.39		
2	100'-0"	0	9590.39	7782.38		
3 0 45'-0" 9531.69 7689.76						
X = HOR	IZONTAL DIS	STANCE, Y = '	VERTICAL DISTA	NCE		

LOCATION POINTS +


POINT


PLOTTED BY: DIVNEY TUNG SCHWALBE, LLP BREANA PARIAN


1	33'-1"	3'-7'
Y = VERT	ZONTAL DIST ICAL DISTAN ROM P.O.B. 1	•

ARC	RADIUS	ANGLE	LENGTH
А	29'-0"	49°	24'-8"
В	30'-6"	48°	25'-9"
С	10'-11"	80°	15'-3"
D	14'-3"	69°	17'-2"
E	43'-9"	22°	17'-2"
F	7'-5"	119°	15'-4"
G	44'-1"	23°	17'-9"
Ι	23'-1"	59°	23'-9"
_	19'-10"	49°	17'-7"
J	17'-8"	56°	17'-4"

3/22/2021 4:34:46 PM M:\2015 PROJECTS\PL15006_SUNY PURCHASE 2015\MKW\CURRENT\L403-L404_ENTRY FOUNTAIN ENLARGEMENT PLAN.DWG

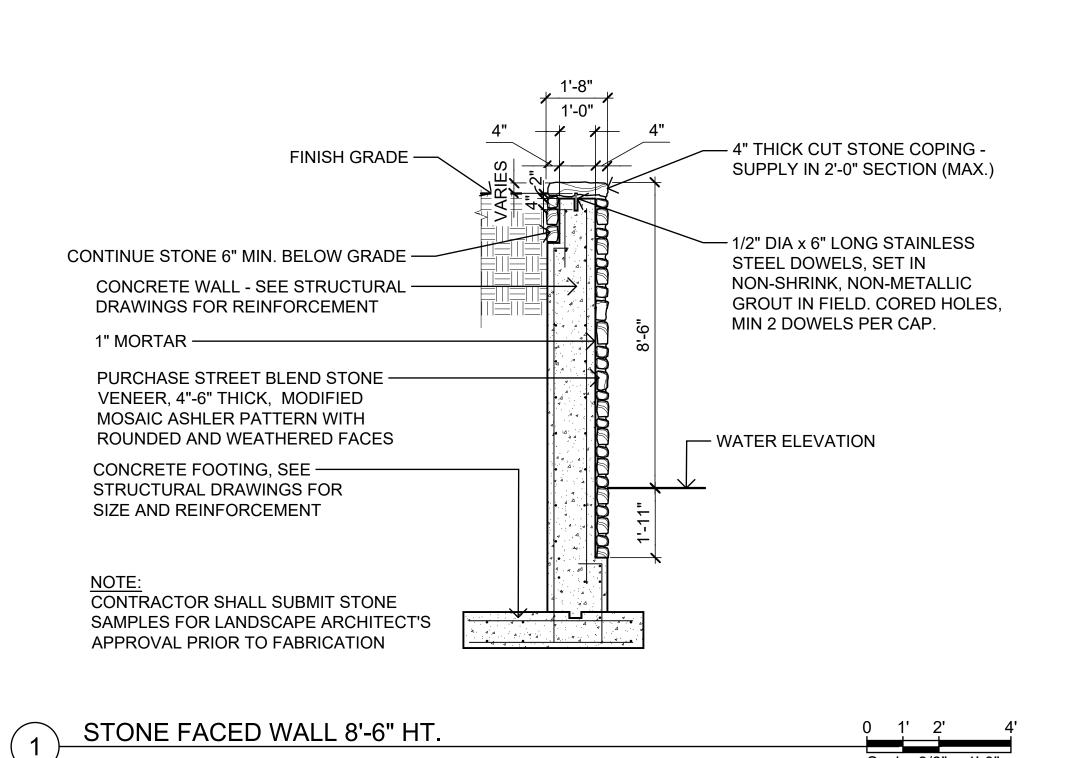

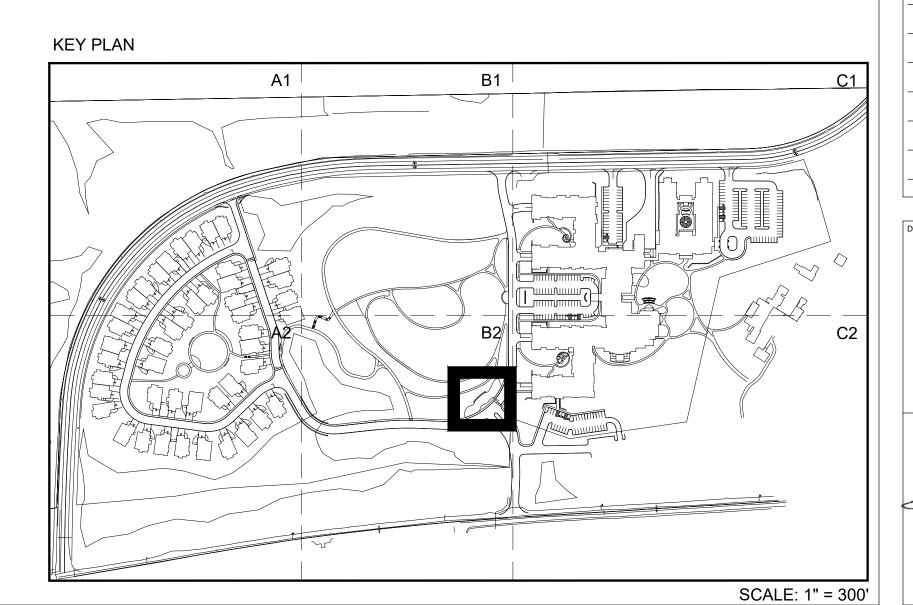

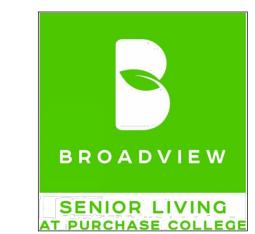

Westchester County, New York

SPONSOR

Purchase College Learning Corporation 735 Anderson Hill Road Purchase, NY 10577-1402

PLANNER, CIVIL ENGINEER

DIVNEY • TUNG • SCHWALBE

Divney Tung Schwalbe, LLP One North Broadway White Plains, NY 10601

F: 914.428.0017

P: 914.428.0010

DEVELOPER

LCS DEVELOPMENT 400 Locust Street, Suite 820 Des Moine, IA 50309

<u>ARCHITECT</u>

HCM Design, Inc. 750 East Pratt Street Baltimore, MD 21202

LANDSCAPE ARCHITECT MKW and Associates, LLC 39 Park Avenue

SURVEYOR

Rutherford, NJ 07070

THE CHAZEN COMPANIES 21 Fox Street

Poughkeepsie, NY 12601

WETLAND CONSULTANT WILLIAM KENNY ASSOCIATES LLC 195 Tunxis Hill Cutoff South Fairfield, CT 06825



NOTE: ALL SITE DESIGN CONCEPTS AND INFORMATION INDICATED OR REPRESENTED BY THIS DRAWING ARE OWNED BY AND ARE THE PROPERTY OF DIVNEY TUNG SCHWALBE, LLP. THIS DRAWING WAS CREATED AND DEVELOPED FOR USE ON, AND IN CONNECTION WITH, THE SPECIFIED PROJECT INDICATED HEREON AND SHALL NOT BE USED BY OR DISCLOSED TO ANY PERSON OR ENTITY WHATSOEVER WITHOUT THE WRITTEN PERMISSION OF DIVNEY


TUNG SCHWALBE, LLP. WRITTEN DIMENSIONS ON THIS DRAWING SHALL HAVE PRECEDENCE OVER SCALED MEASUREMENTS. CONTRACTOR SHALL VERIFY AND BE RESPONSIBLE FOR ALL DIMENSIONS AND CONDITIONS ON THE JOB AND THIS OFFICE MUST BE NOTIFIED OF ANY VARIATIONS FROM DIMENSIONS AND CONDITIONS SHOWN BY


LEGAL NOTICE: IT IS A VIOLATION OF ARTICLE 145 OF THE NEW YORK STATE EDUCATION LAW FOR ANY PERSON TO ALTER THIS DOCUMENT IN ANY WAY EXCEPT AS PROVIDED IN SECTION 7209 (2), ARTICLE 145, NEW YORK STATE EDUCATION LAW.

© Copyright Divney Tung Schwalbe, LLP 2019 All rights reserved.

VISI	ONS	
).	DATE	ISSUE

ENTRY FOUNTAIN LAYOUT AND **MATERIALS** ENLARGEMENT PLAN

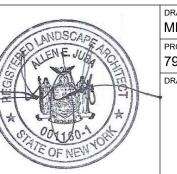

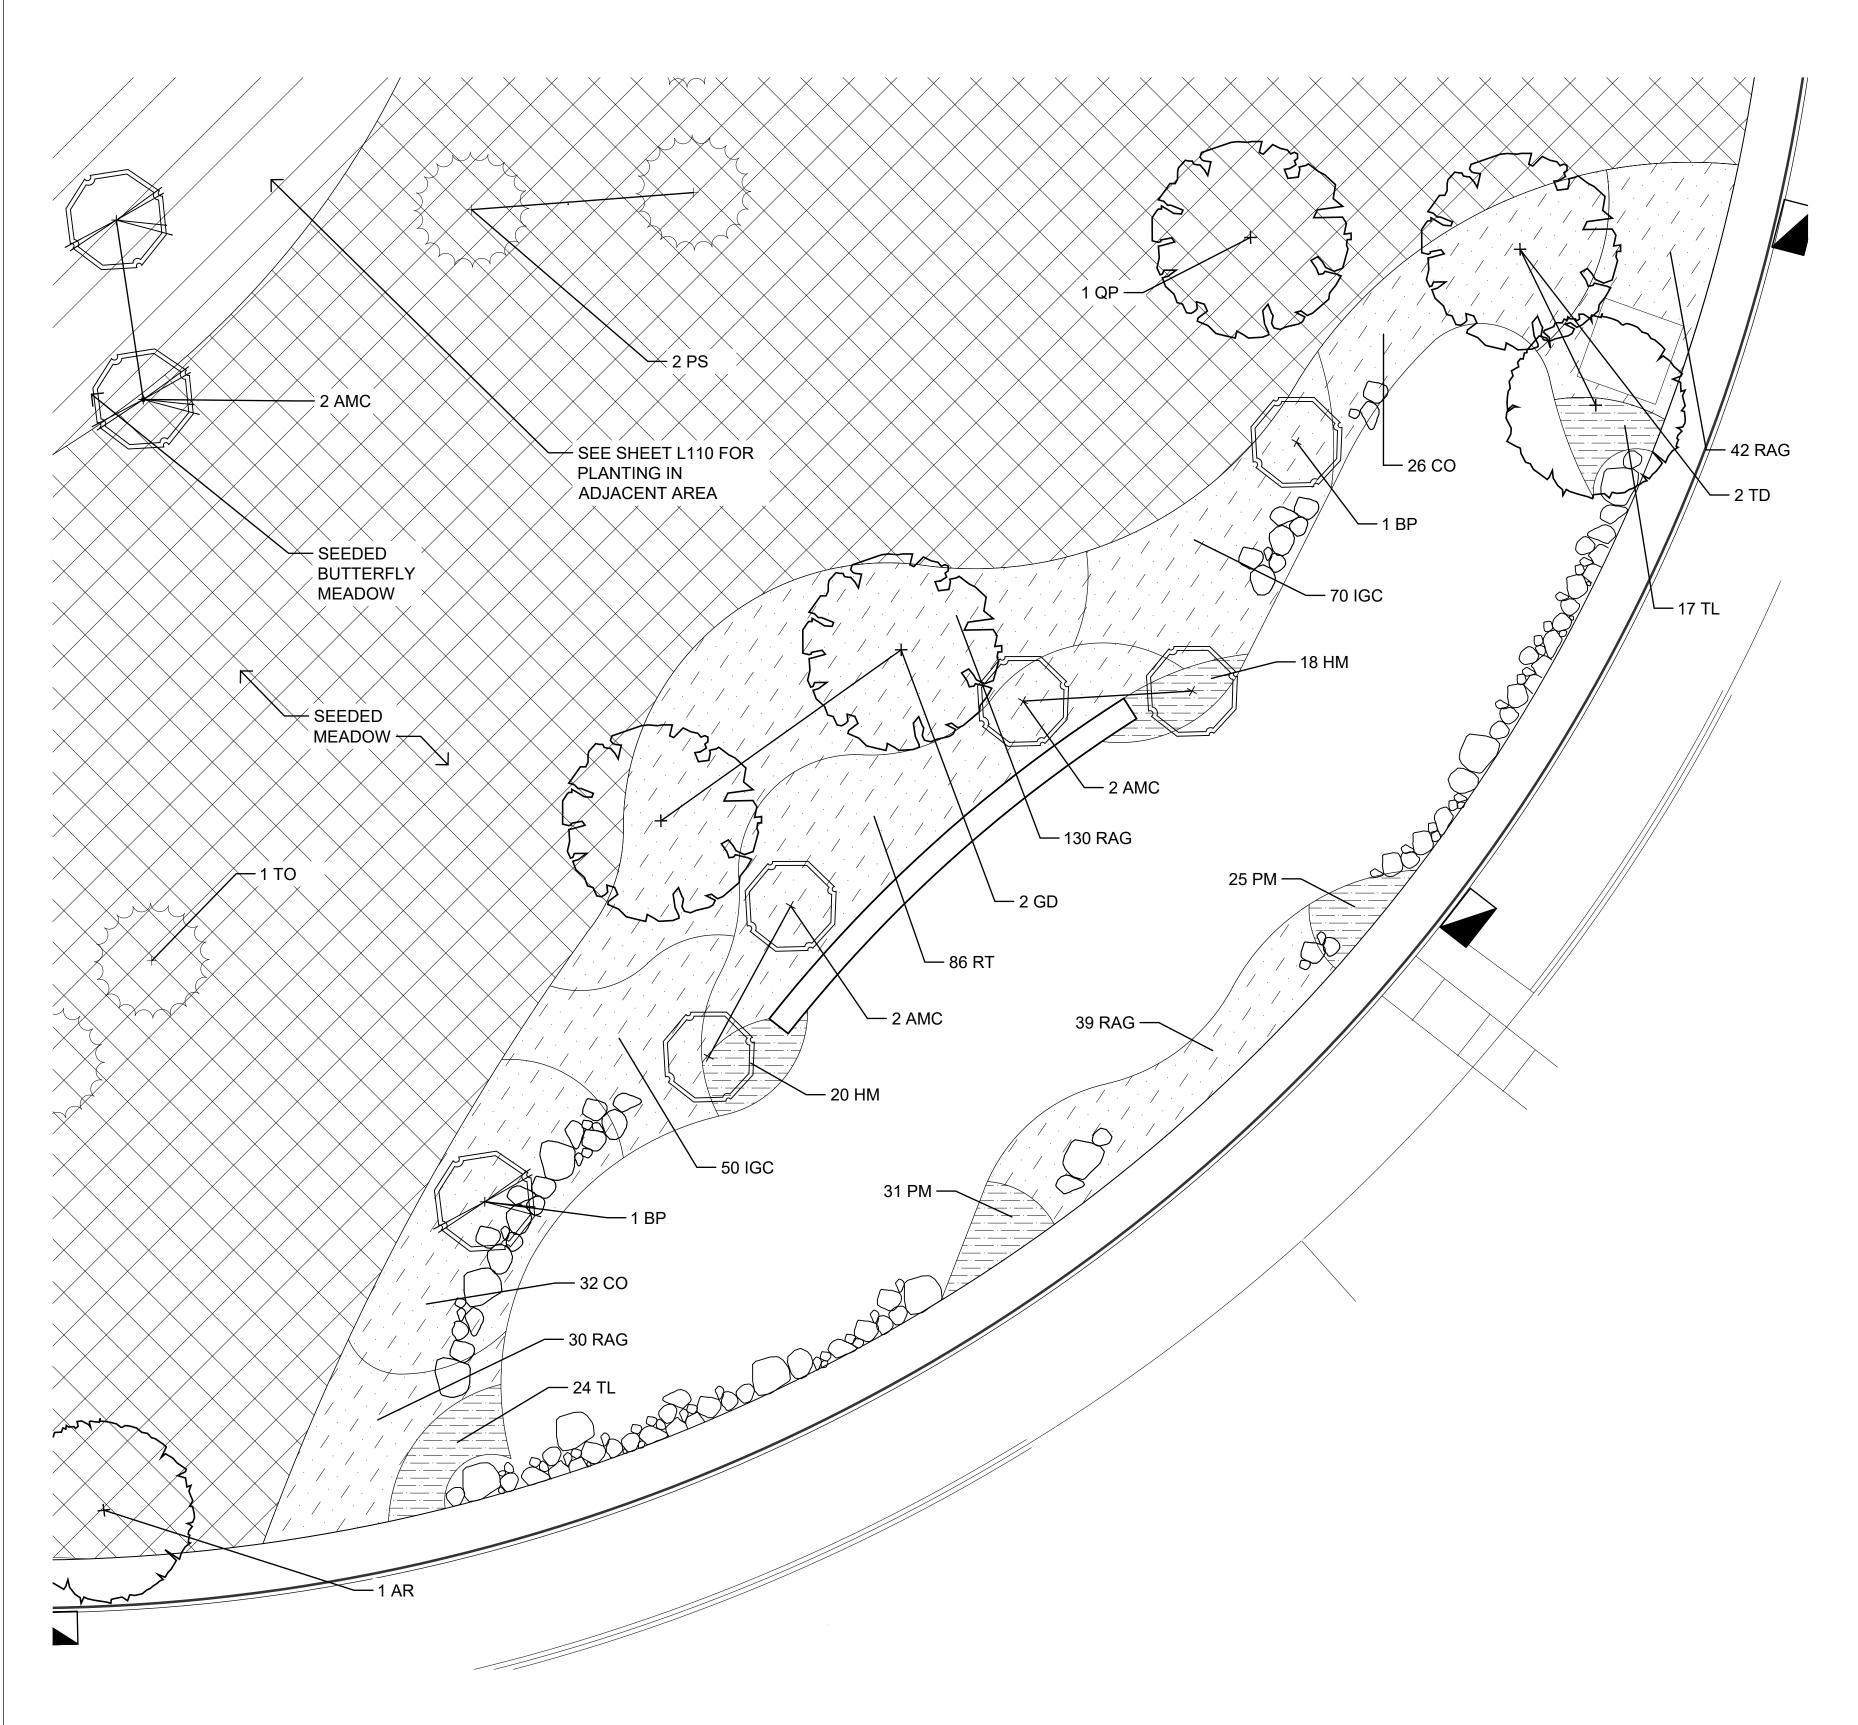


PLOTTED BY: DIVNEY TUNG SCHWALBE, LLP BREANA PARIAN 3/22/2021 4:34:51 PM M:\2015 PROJECTS\PL15006_SUNY PURCHASE 2015\MKW\CURRENT\L403-L404_ENTRY FOUNTAIN ENLARGEMENT PLAN.DWG


PLANTING SCHEDULE

r L Ai	IN I IIN	G SCHEDULE					
	KEY	BOTANICAL NAME	COMMON NAME	SIZE	ROOT	SPACING	NOTES
SHADE	E TREES	S	1	1			
1	AR	Acer rubrum 'Redpointe'	Redpointe Red Maple	2" - 2.5" CAL.	B&B	AS PER PLAN	BRANCHED 6-7' FROM GROUND. SINGLE, STRAIGHT TRUNK WITH LEADER INTACT AND SYMMETRICAL WELL-BRANCHED TOP
2	GD	Gymnocladus dioicus	Kentucky Coffee Tree	2" - 2.5" CAL.	B&B	AS PER PLAN	BRANCHED 6-7' FROM GROUND, AVERAGE HEIGHT OF 11-12'. SPREAD OF TOP 4-5'.
1	QP	Quercus palustris	Pin Oak	2" - 2.5" CAL.	B&B	AS PER PLAN	BRANCHED 6-7' FROM GROUND, AVERAGE HEIGHT OF 11-12'. SPREAD OF TOP 4-5'.
2	ТО	Thuja occidentalis	Arborvitae	6' - 7' HT.	B&B	AS PER PLAN	VIGOROUS, SINGLE STEM.
EVERO	GREEN	TREES	•	•			
2	PS	Pinus strobus	Eastern White Pine	6' - 7' HT.	B&B	AS PER PLAN	VIGOROUS, SINGLE STEM. NO LIMB CUTS OVER 3/4" WHICH HAVE NOT COMPLETELY CALLUSED OVER.
1	PT	Pinus thunbergii	Japanese Black Pine	6' - 7' HT.	B&B	AS PER PLAN	VIGOROUS, SINGLE STEM. NO LIMB CUTS OVER 3/4" WHICH HAVE NOT COMPLETELY CALLUSED OVER.
ORNAI	MENTAL	L TREES	•	•			
6	AMC	Amelanchier canadensis	Serviceberry	2" - 2.5" CAL.	B&B	AS PER PLAN	MULTISTEM
2	BP	Betula populifolia	Grey Birch	5' - 6' HT.	B&B	AS PER PLAN	CLUMP FORM HAVING 3 OR MORE MAIN STEMS ARISING FROM THE MAIN TRUNK, NOT MORE THAN 6" FROM GROUND LEVEL.
DECID	UOUS S	SHRUBS		•			
58	СО	Cephalanthus occidentalis	Buttonbush	15" - 18" HT.	B&B OR CONTAINER	48" O.C.	HEAVY, WELL-BRANCHED TOP.
241	RAG	Rhus aromatica 'Gro-Low'	Gro-Low Sumac	3 GAL.	B&B OR CONTAINER	36" O.C.	VIGOROUS, DENSE, LOW.
86	RT	Rhus typhina 'Bailtiger'	Tiger Eye Sumac	18" - 24" HT.	B&B OR CONTAINER	36" O.C.	MULTISTEM
EVERO	GREEN	SHRUBS		•			
120	IGC	llex glabra 'Compacta'	Compact Inkberry Holly	18" - 24" HT.	B&B OR CONTAINER	30" O.C.	WELL-ESTABLISHED IN CONTAINER
PEREN	NIALS		•	•			
38	НМ	Hibiscus moscheutos	Swamp Rose Mallow	2 GAL.	CONTAINER	24" O.C.	WELL-ESTABLISHED IN CONTAINER.
56	PM	Pycnanthemum muticum	Mountain Mint	1 GAL.	CONTAINER	18" O.C.	WELL-ESTABLISHED IN CONTAINER.
41	TL	Typha latifolia	Cattail	1 GAL.	CONTAINER	24" O.C.	WELL-ESTABLISHED IN CONTAINER

LEGEND

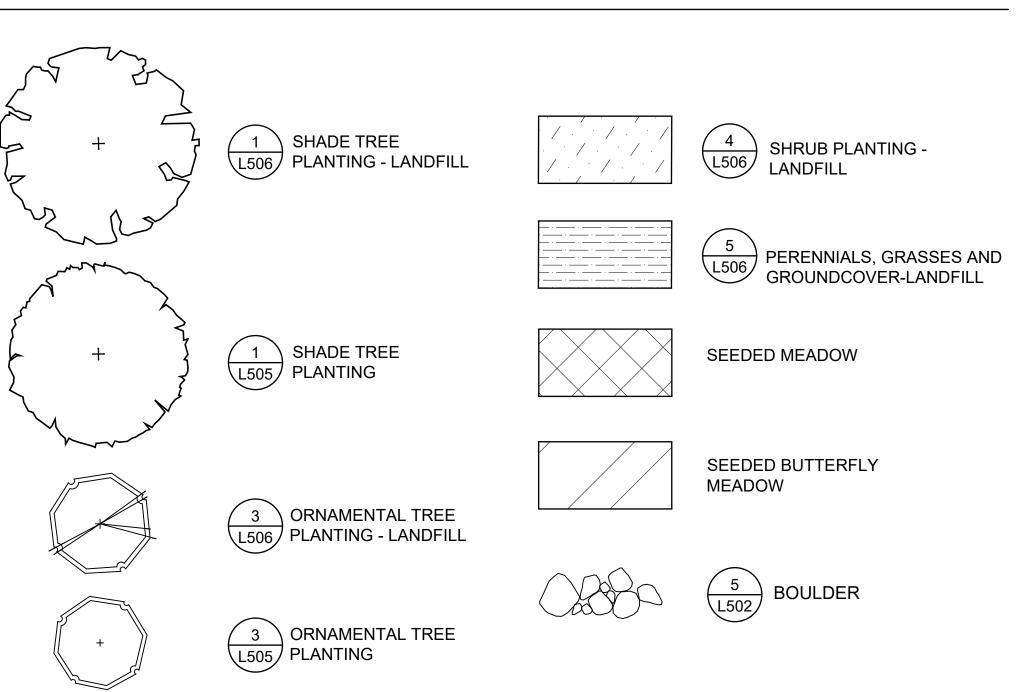

EVERGREEN TREE PLANTING - LANDFILL

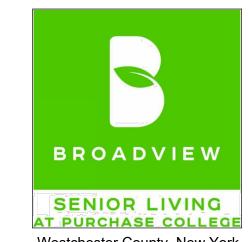

Westchester County, New York

SPONSOR

Purchase College Learning Corporation 735 Anderson Hill Road Purchase, NY 10577-1402

PLANNER, CIVIL ENGINEER

DIVNEY • TUNG • SCHWALBE Intelligent Land U

Divney Tung Schwalbe, LLP One North Broadway White Plains, NY 10601

P: 914.428.0010 F: 914.428.0017

DEVELOPER LCS DEVELOPMENT 400 Locust Street, Suite 820 Des Moine, IA 50309

<u>ARCHITECT</u> HCM Design, Inc. 750 East Pratt Street

Baltimore, MD 21202 LANDSCAPE ARCHITECT MKW and Associates, LLC 39 Park Avenue

Rutherford, NJ 07070 SURVEYOR THE CHAZEN COMPANIES 21 Fox Street

Poughkeepsie, NY 12601

WETLAND CONSULTANT WILLIAM KENNY ASSOCIATES LLC 195 Tunxis Hill Cutoff South Fairfield, CT 06825



NOTE: ALL SITE DESIGN CONCEPTS AND INFORMATION INDICATED OR REPRESENTED BY THIS DRAWING ARE OWNED BY AND ARE THE PROPERTY OF DIVNEY TUNG SCHWALBE, LLP. THIS DRAWING WAS CREATED AND DEVELOPED FOR USE ON, AND IN CONNECTION WITH, THE SPECIFIED PROJECT INDICATED HEREON AND SHALL NOT BE USED BY OR DISCLOSED TO ANY PERSON OR ENTITY WHATSOEVER WITHOUT THE WRITTEN PERMISSION OF DIVNEY TUNG SCHWALBE, LLP.

WRITTEN DIMENSIONS ON THIS DRAWING SHALL HAVE PRECEDENCE OVER SCALED MEASUREMENTS. CONTRACTOR SHALL VERIFY AND BE RESPONSIBLE FOR ALL DIMENSIONS AND CONDITIONS ON THE JOB AND THIS OFFICE MUST BE NOTIFIED OF ANY VARIATIONS FROM DIMENSIONS AND CONDITIONS SHOWN BY THESE DRAWINGS.


LEGAL NOTICE: IT IS A VIOLATION OF ARTICLE 145 OF THE NEW YORK STATE EDUCATION LAW FOR ANY PERSON TO ALTER THIS DOCUMENT IN ANY WAY EXCEPT AS PROVIDED IN SECTION 7209 (2), ARTICLE 145, NEW YORK STATE EDUCATION LAW.


© Copyright Divney Tung Schwalbe, LLP 2019 All rights reserved.


ENTRY FOUNTAIN


PLANTING **ENLARGEMENT PLAN**




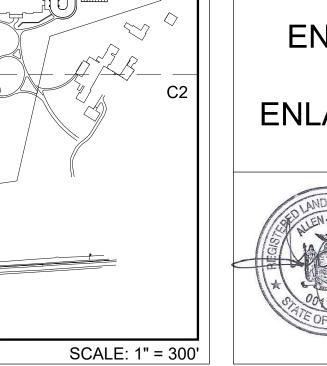

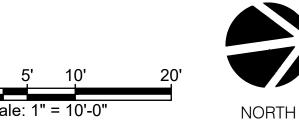

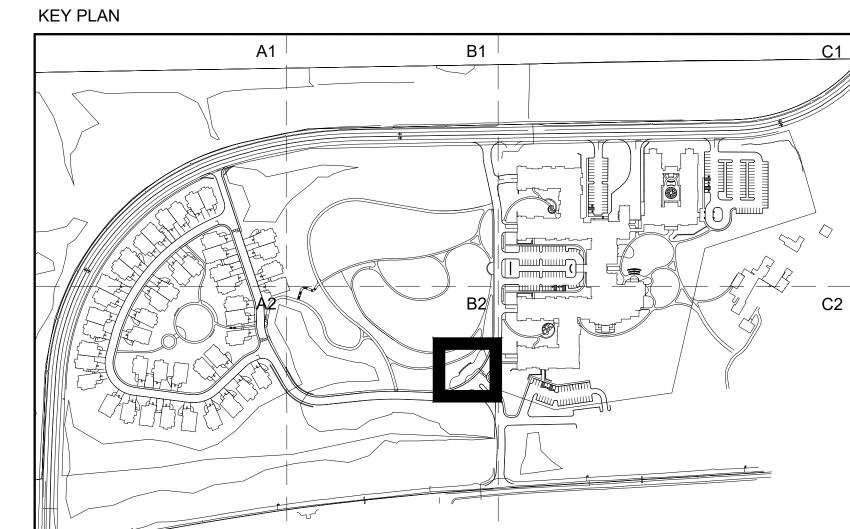

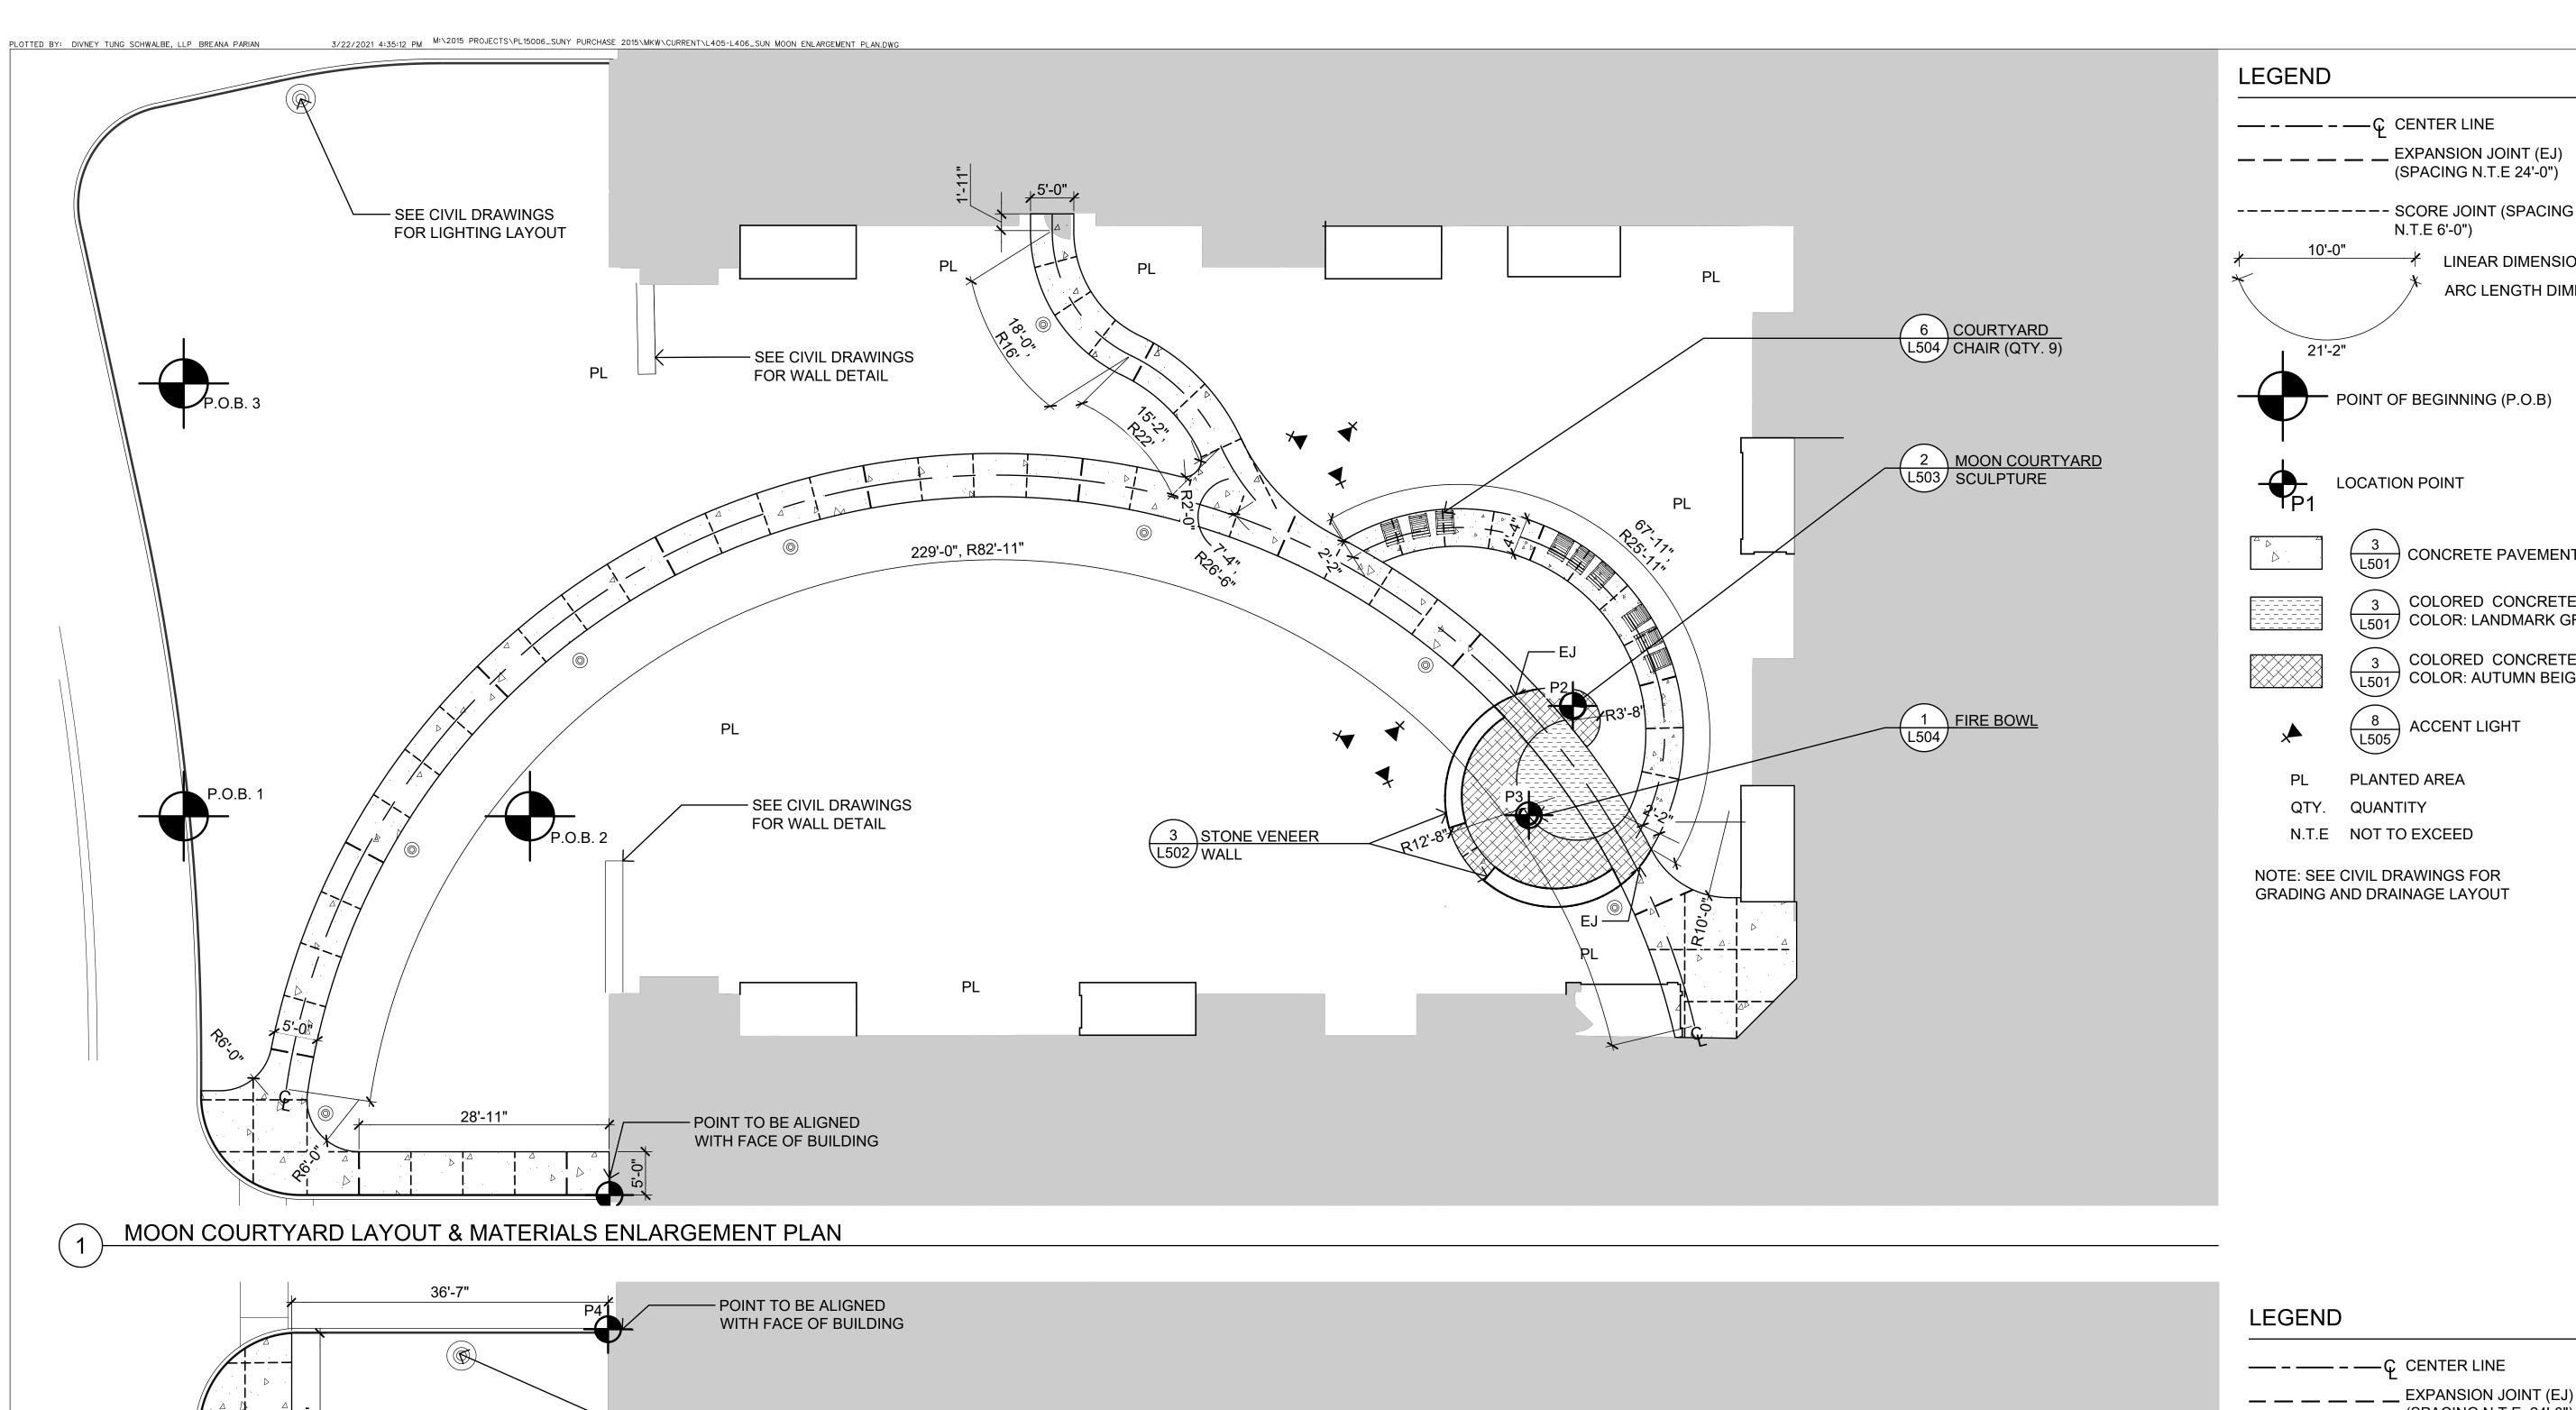

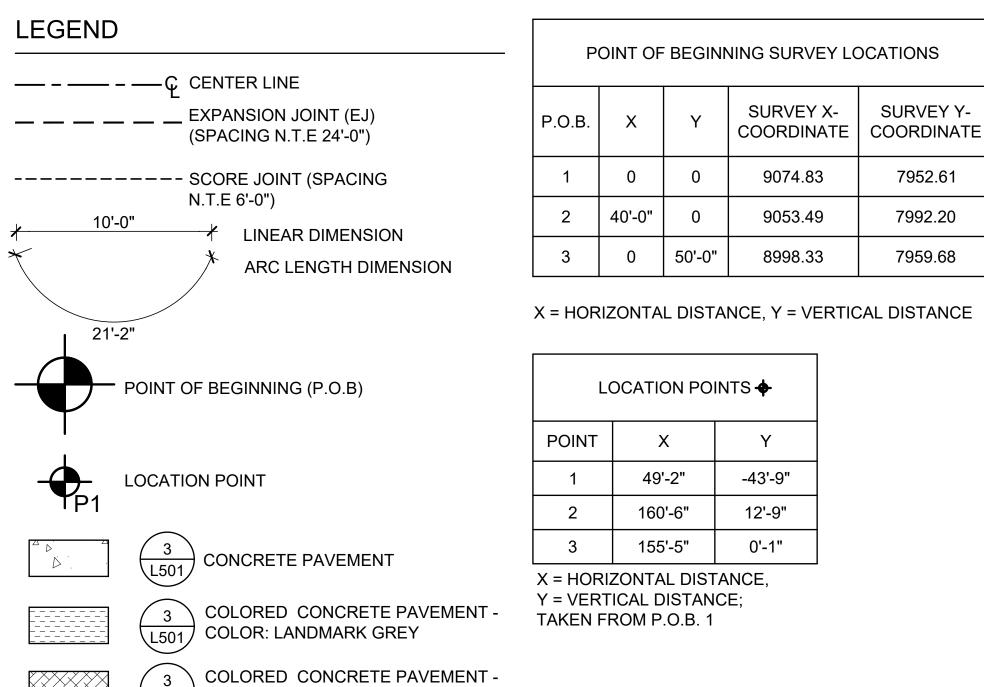

COLOR: AUTUMN BEIGE

(SPACING N.T.E. 24'-0")

LINEAR DIMENSION

 $\frac{7}{1501}$ CONCRETE PAVEMENT

COLOR: SUN BAKED CLAY

ARC LENGTH DIMENSION

---- SCORE JOINT (SPACING

N.T.E. 6'-0")

LOCATION POINT

ACCENT LIGHT

PLANTED AREA

QUANTITY



SURVEY Y-

7952.61

7992.20

7959.68

LOCATION POINTS +

-320'-1"

-366'-0"

-386'-5"

49'-3"

142'-0"

142'-11"

1. LOCATION POINTS TAKEN FROM

2. LOCATION POINTS CONTINUED

X = HORIZONTAL DISTANCE, Y = VERTICAL DISTANCE;

P.O.B 1 LOCATED ON 1/L405

POINT

NOTES:

FROM 1/L405

SENIOR LIVING AT PURCHASE COLLEGE Westchester County, New York

SPONSOR

Purchase College Learning Corporation 735 Anderson Hill Road Purchase, NY 10577-1402

PLANNER, CIVIL ENGINEER

DIVNEY • TUNG • SCHWALBE

Divney Tung Schwalbe, LLP One North Broadway White Plains, NY 10601

P: 914.428.0010 F: 914.428.0017

DEVELOPER LCS DEVELOPMENT 400 Locust Street, Suite 820

ARCHITECT

Des Moine, IA 50309

HCM Design, Inc. 750 East Pratt Street Baltimore, MD 21202

LANDSCAPE ARCHITECT MKW and Associates, LLC 39 Park Avenue

SURVEYOR THE CHAZEN COMPANIES

Poughkeepsie, NY 12601

Fairfield, CT 06825

Rutherford, NJ 07070

21 Fox Street

WETLAND CONSULTANT WILLIAM KENNY ASSOCIATES LLC 195 Tunxis Hill Cutoff South

NOTE: ALL SITE DESIGN CONCEPTS AND INFORMATION INDICATED OR REPRESENTED BY THIS DRAWING ARE OWNED BY AND ARE THE OR REPRESENTED BY THIS DRAWING ARE OWNED BY AND ARE THE PROPERTY OF DIVNEY TUNG SCHWALBE, LLP. THIS DRAWING WAS CREATED AND DEVELOPED FOR USE ON, AND IN CONNECTION WITH, THE SPECIFIED PROJECT INDICATED HEREON AND SHALL NOT BE USED BY OR DISCLOSED TO ANY PERSON OR ENTITY WHATSOEVER WITHOUT THE WRITTEN PERMISSION OF DIVNEY TUNG SCHWALBE, LLP.

WRITTEN DIMENSIONS ON THIS DRAWING SHALL HAVE PRECEDENCE OVER SCALED MEASUREMENTS. CONTRACTOR SHALL VERIFY AND BE RESPONSIBLE FOR ALL DIMENSIONS AND CONDITIONS ON THE JOB AND THIS OFFICE MUST BE NOTIFIED OF ANY VARIATIONS FROM DIMENSIONS AND CONDITIONS SHOWN BY THESE DRAWINGS. LEGAL NOTICE: IT IS A VIOLATION OF ARTICLE 145 OF THE NEW YORK STATE EDUCATION LAW FOR ANY PERSON TO ALTER THIS


DOCUMENT IN ANY WAY EXCEPT AS PROVIDED IN SECTION 7209 (2),

ARTICLE 145, NEW YORK STATE EDUCATION LAW. © Copyright Divney Tung Schwalbe, LLP 2019 All rights reserved.


SUN & MOON COURTYARD LAYOUT & MATERIALS


ENLARGEMENT PLAN

L405

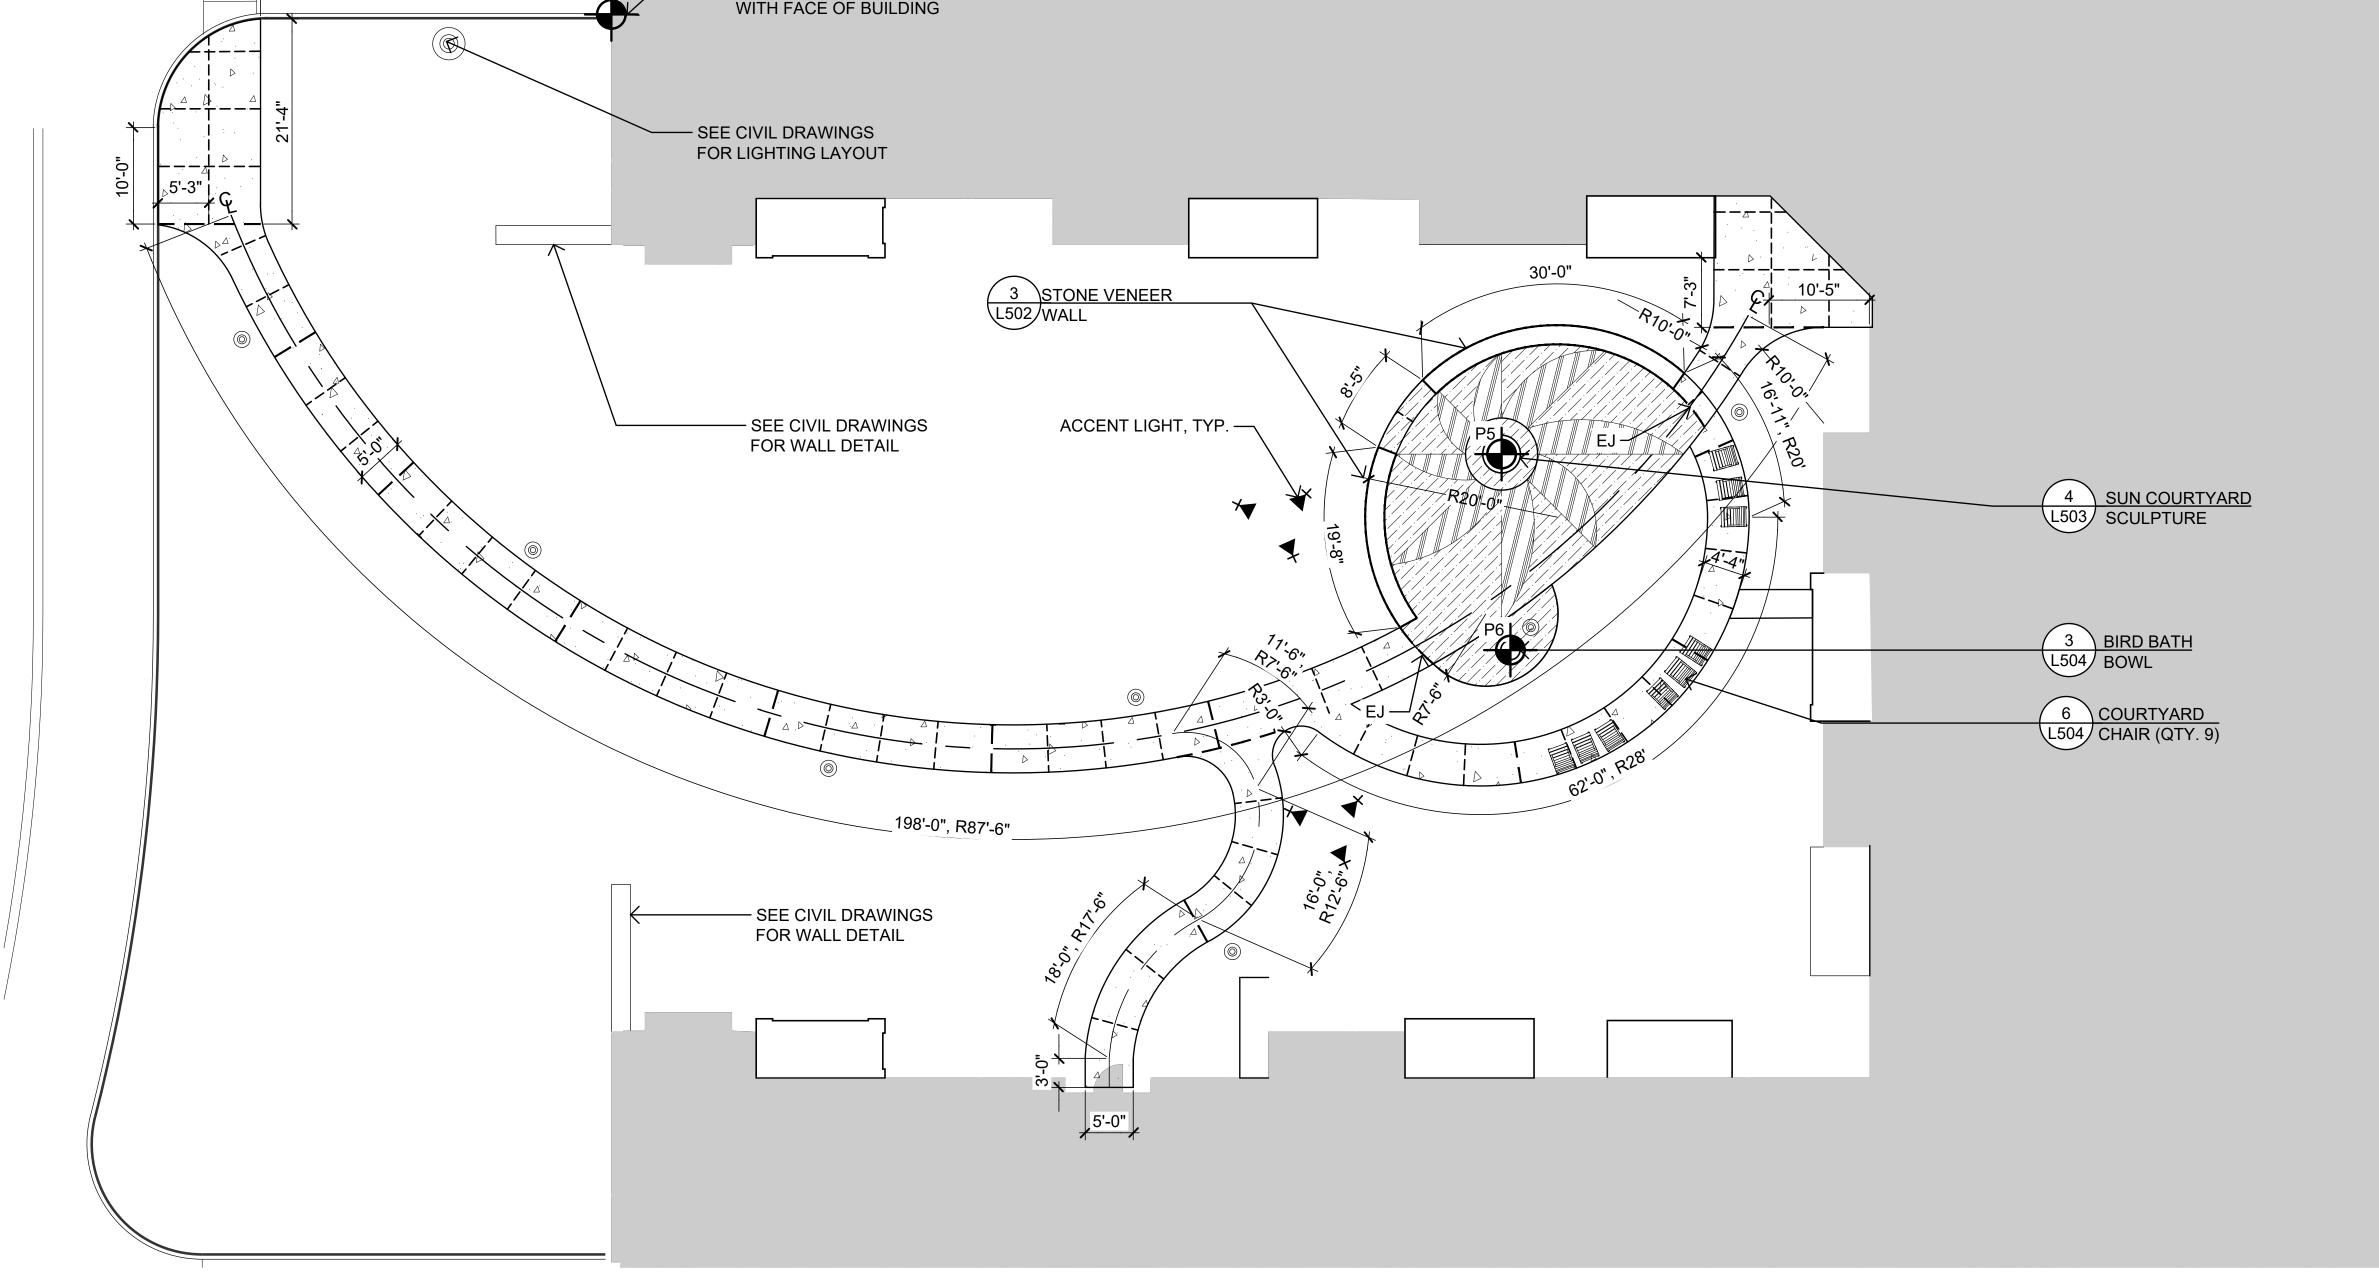


SUN COURTYARD LAYOUT & MATERIALS ENLARGEMENT PLAN

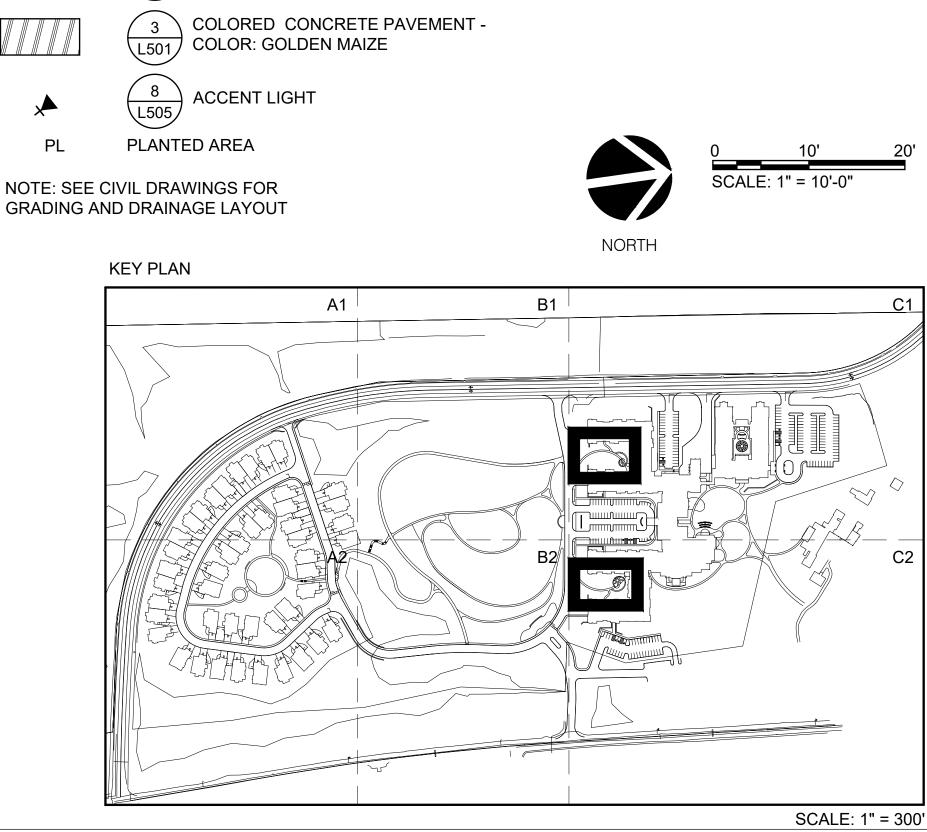


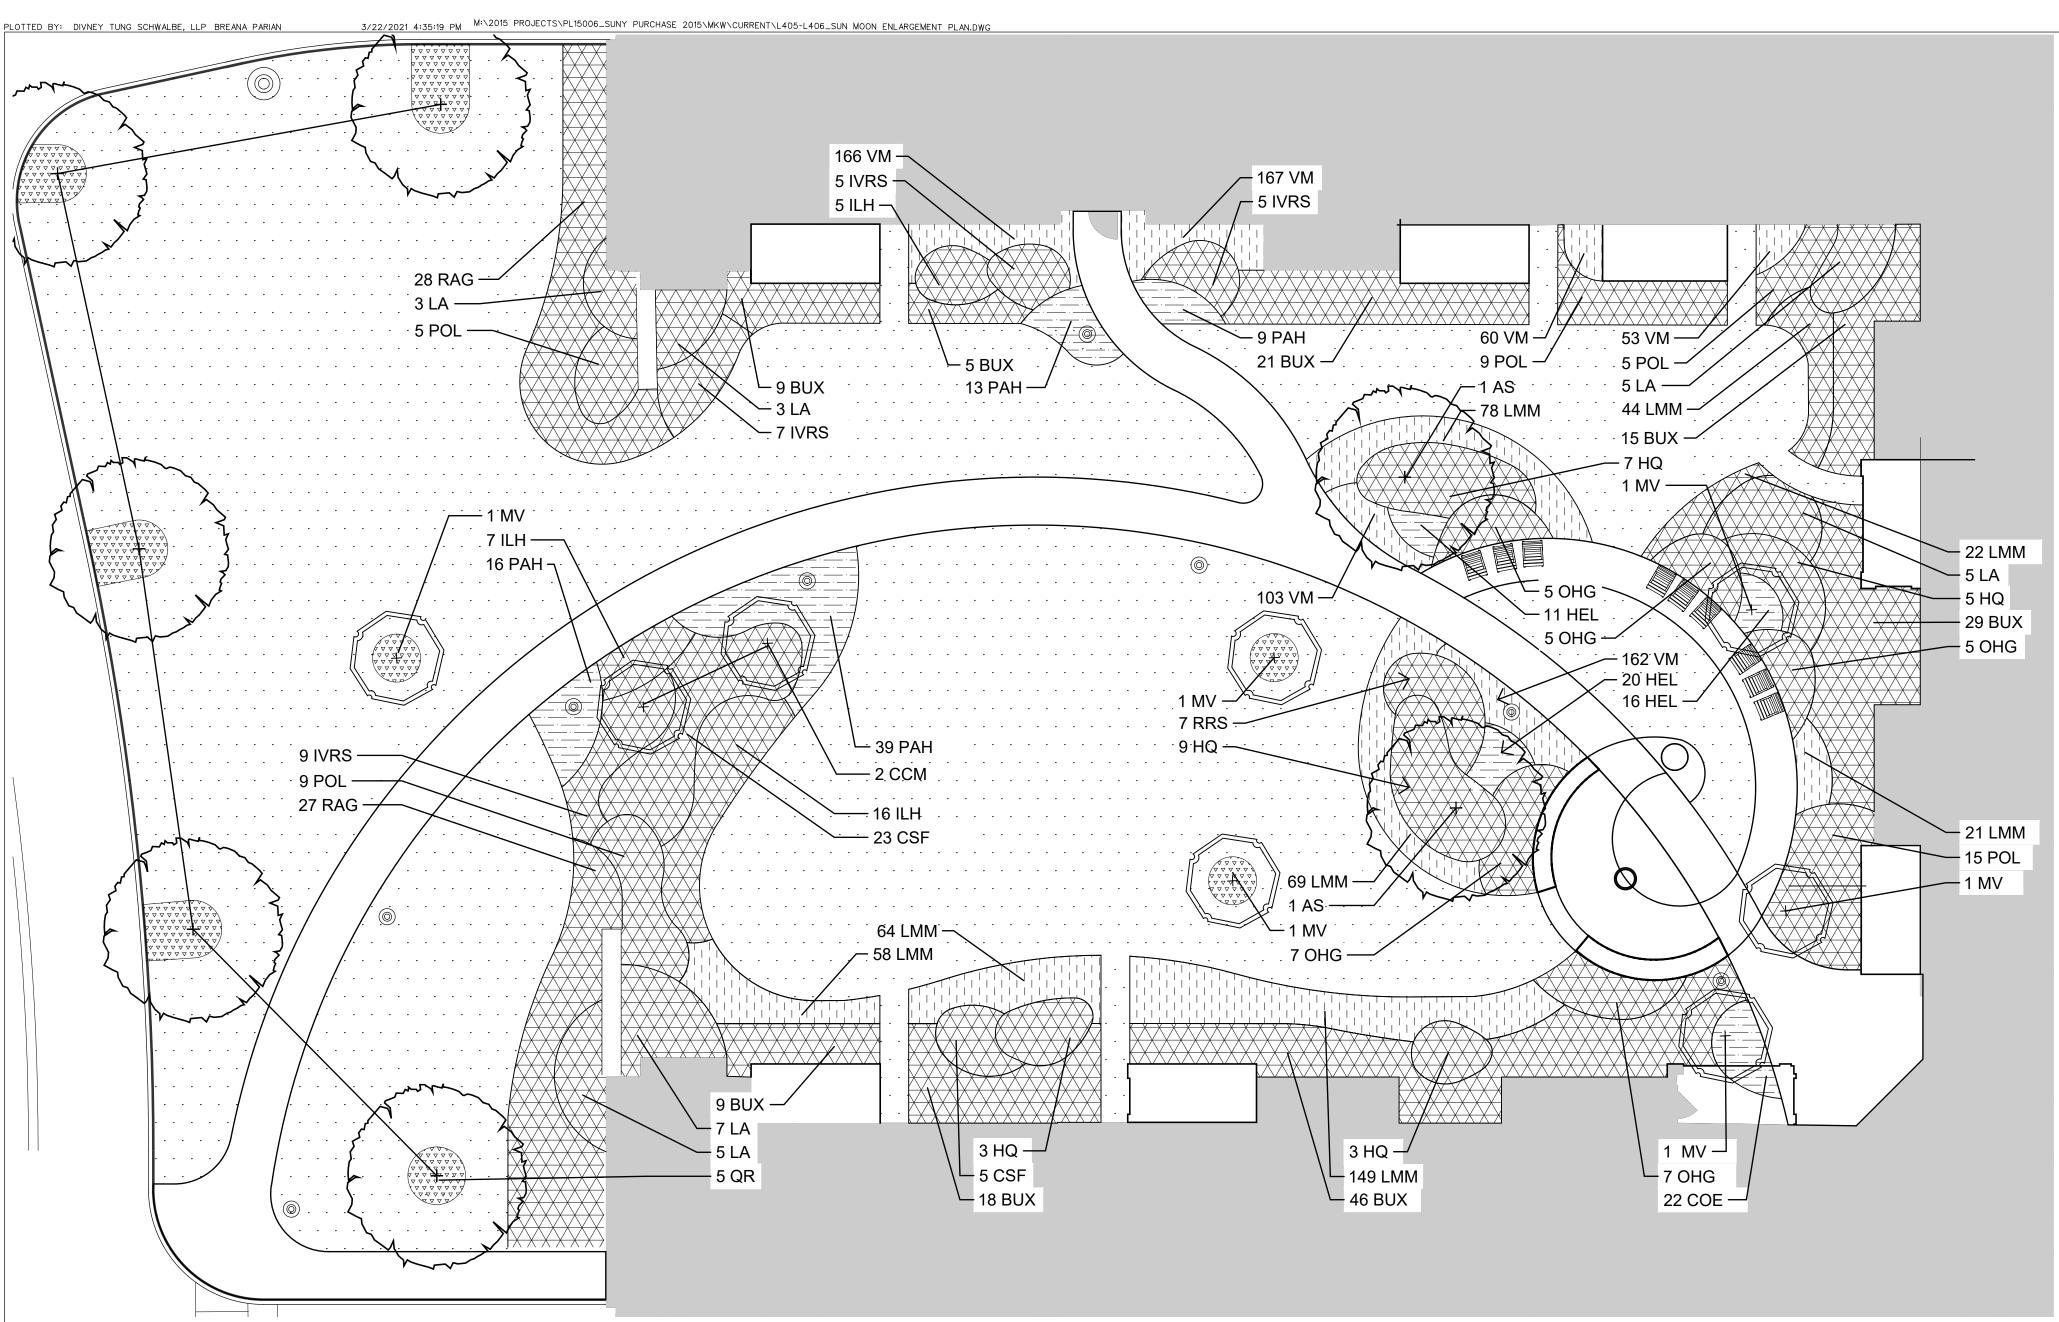


MOON COURTYARD - PLANTING PLAN

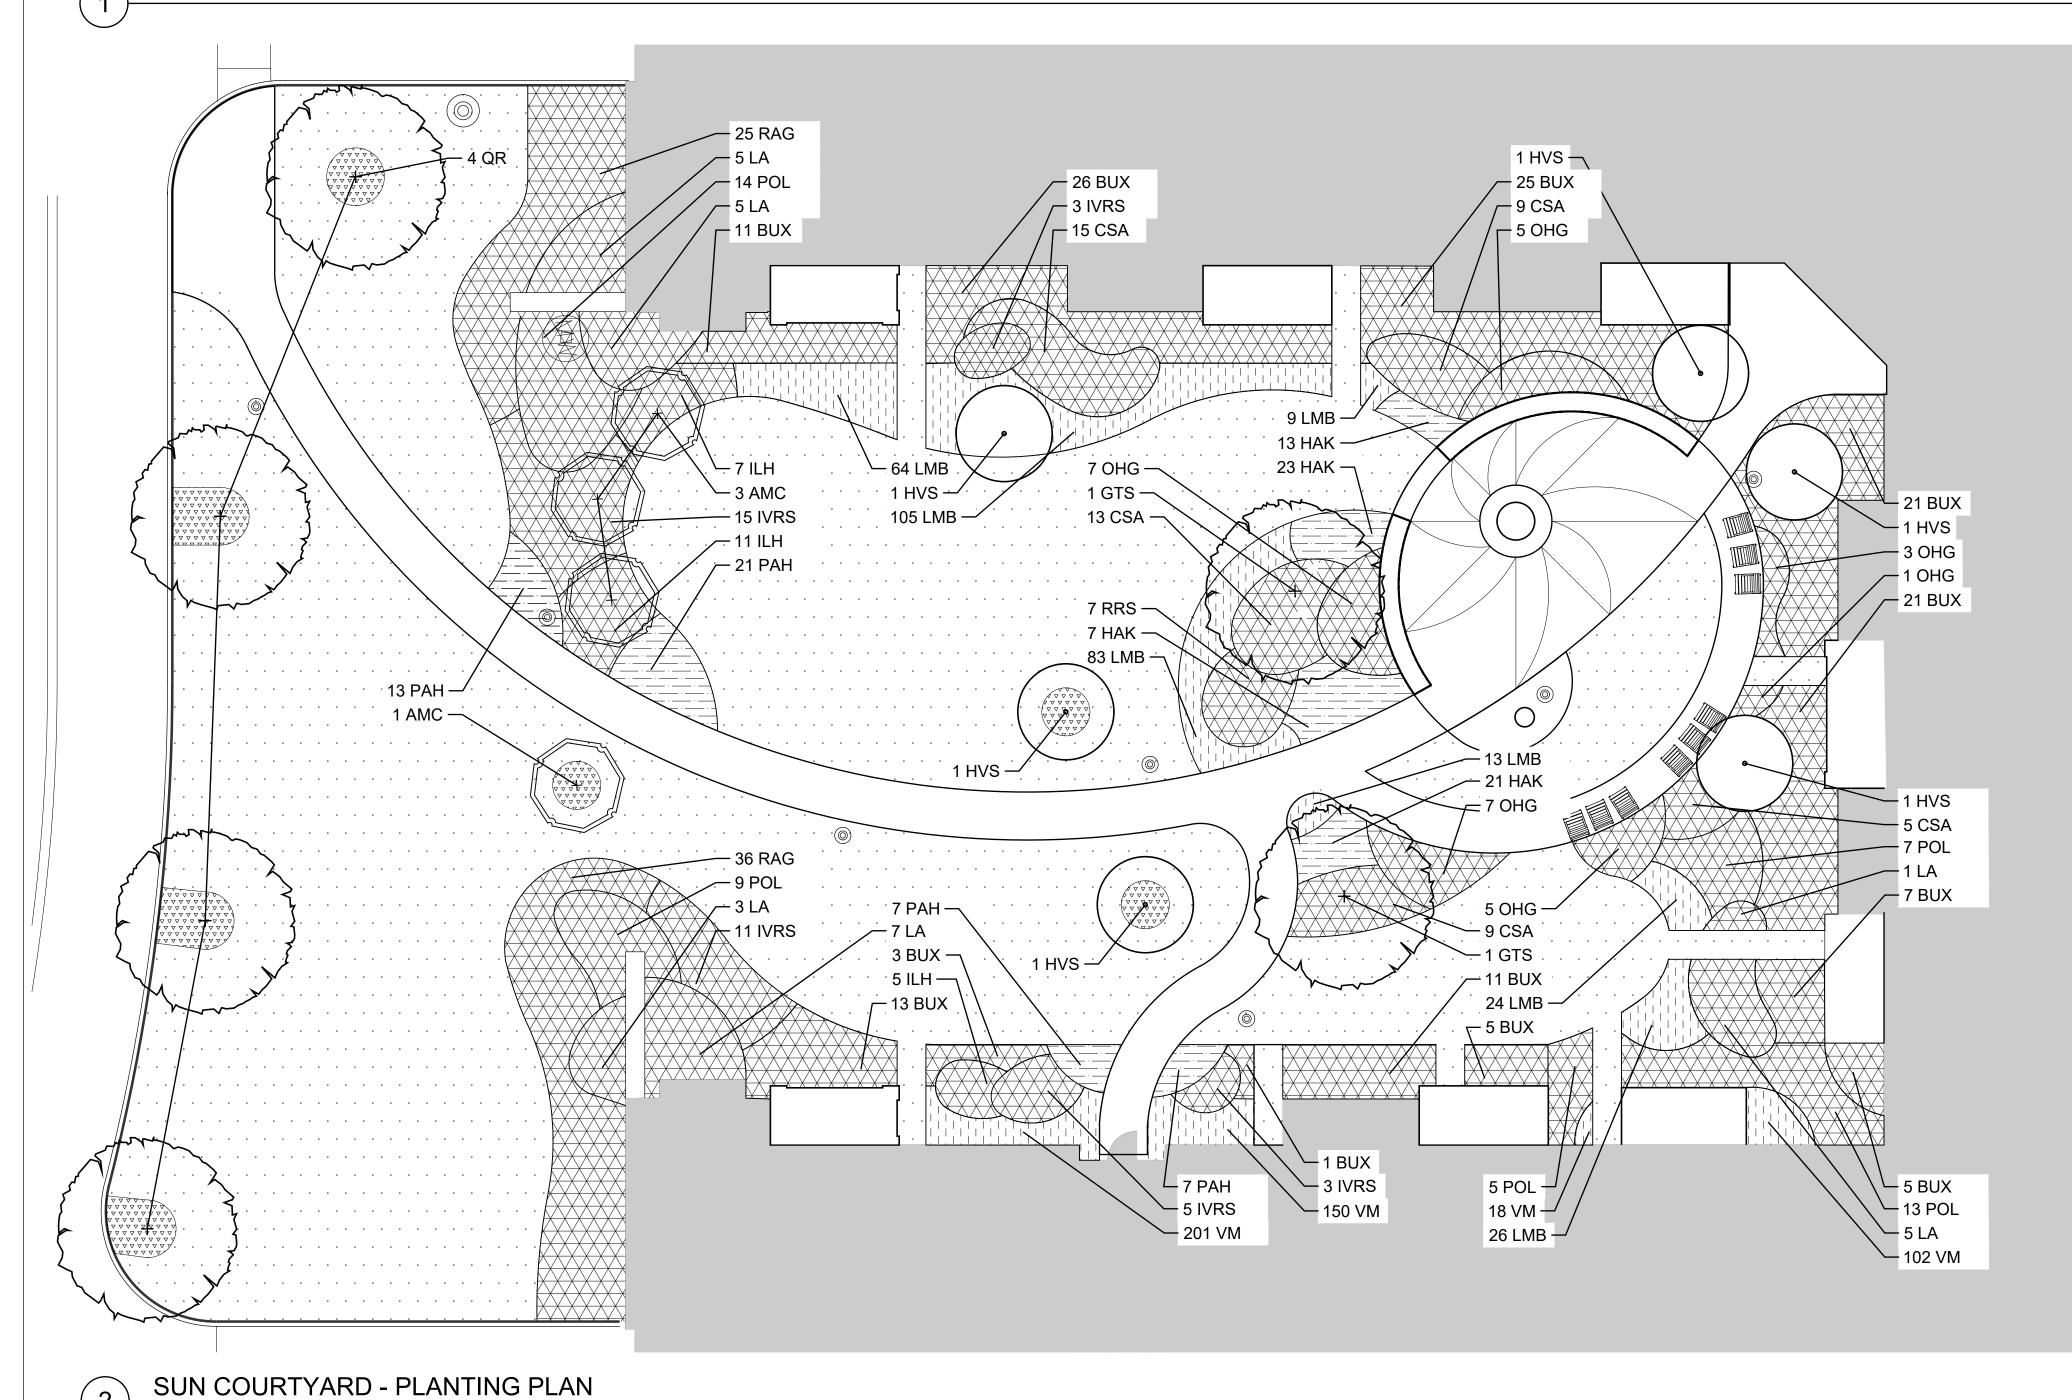


LEGEND

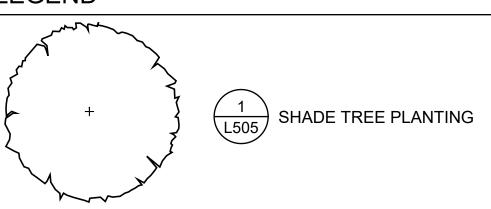




 


   











L505 GRASSES PLANTING

 

MULCH - 2" DEPTH

 

 $\frac{\binom{6}{1505}}{\binom{1}{1505}}$ GROUNDCOVER PLANTING

PLANTING SCHEDULE

ı				 		<u> </u>	
QTY.	KEY	BOTANICAL NAME	COMMON NAME	SIZE	ROOT	SPACING	NOTES
SHADE	TREES	6					
15	AS	Acer saccharum 'Legacy'	Legacy Sugar Maple	2" - 2.5" CAL.	B&B	AS PER PLAN	BRANCHED 6-7' FROM GROUND. SINGLE, STRAIGHT TRUNK WITH LEADER INTACT AND SYMMETRICAL WELL-BRANCHED TOP
10	QR	Quercus rubra	Northern Red Oak	2" - 2.5" CAL.	В&В	AS PER PLAN	BRANCHED 6-7' FROM GROUND, AVERAGE HEIGHT OF 11-12'. SPREAI OF TOP 4-5'.
ORNAN	MENTAL	_ TREES					
1	AMC	Amelanchier canadensis	Serviceberry	5' - 6' HT.	B&B	AS PER PLAN	MULTI-STEM
2	ССМ	Cercis canadensis 'Merlot'	Eastern Redbud	5' - 6' HT.	B&B	AS PER PLAN	VIGOROUS, SINGLE STEM, SYMMETRICAL.
6	MV	Magnolia virginiana	Sweetbay Magnolia	6' - 7' HT.	В&В	AS PER PLAN	VIGOROUS, SINGLE STEM, SYMMETRICAL.
DECID	uous s	SHRUBS					
51	CSA	Cornus sanguinea 'Arctic Sun'	Arctic Sun Dogwood	12" - 15" HT.	B&B OR CONTAINER	36" O.C.	VIGOROUS, DENSE, SYMMETRICAL.
28	CSF	Cornus stolonifera 'Farrow'	Red Twig Dogwood	12" - 15" HT.	B&B OR CONTAINER	36" O.C.	VIGOROUS, DENSE, SYMMETRICAL.
5	HVS	Hamamelis vernalis 'Sandra'	Ozark Witch Hazel	15" - 18" HT.	B&B	AS PER PLAN	HEAVY, WELL-BRANCHED TOP.
27	HQ	Hydrangea quercifolia	Oak Leaf Hydrangea	15" - 18" HT.	B&B OR CONTAINER	48" O.C.	VIGOROUS, SYMMETRICAL.
51	ILH	Itea virginica 'Little Henry'	Virginia Sweetspire	12" - 15" HT.	B&B OR CONTAINER	36" O.C.	VIGOROUS, DENSE, SYMMETRICAL.
63	IVRS	llex verticillata "Red Sprite'	Red Sprite Winterberry	15" - 18" HT.	B&B OR CONTAINER	42" O.C.	VIGOROUS, DENSE, SYMMETRICAL.
54	LA	Lindera angustifolia	Oriental Spicebush	12" - 15" HT.	B&B OR CONTAINER	48" O.C.	VIGOROUS, DENSE, SYMMETRICAL.
110	RAG	Rhus aromatica 'Gro-Low'	Dwarf Fragrant Sumac	12" - 15" HT.	B&B OR CONTAINER	42" O.C.	VIGOROUS, DENSE, LOW
14	RRS	Rosa rugosa 'Meitozaure'	Rosa x 'Radsunny'	12" - 15" HT.	B&B OR CONTAINER	42" O.C.	VIGOROUS, DENSE, FREE OF DISEASE.
EVERG	REEN :	SHRUBS					
301	BUX	Buxus semipervirens 'Suffruticosa'	Compact Boxwood	12" - 15" HT.	CONTAINER	36" O.C.	WELL-ESTABLISHED IN CONTAINER
57	OHG	Osmanthus heterophyllus 'Goshiki'	Goshiki False Holly	15" - 18" HT.	CONTAINER	42" O.C.	WELL-ESTABLISHED IN CONTAINER
91	POL	Prunus laurocerasus 'Otto Luyken'	Cherry Laurel	15" - 18" HT.	CONTAINER	42" O.C.	WELL-ESTABLISHED IN CONTAINER
PEREN	INIALS						
22	COE	Carex oshimensis 'Evergold'	Evergold Sedge	2 GAL.	CONTAINER	18" O.C.	WELL-ESTABLISHED IN CONTAINER
47	HEL	Helleborus orientalis	Lenten Rose	2 GAL.	CONTAINER	15" O.C.	WELL-ESTABLISHED IN CONTAINER
GRASS	SES						
64	HAK	Hakonechloa macra 'All Gold'	Golden Japanese Forest Grass	1 GAL.	CONTAINER	18" O.C.	WELL-ESTABLISHED IN CONTAINER
125	PAH	Pennisetum alopecurides 'Hameln'	Fountain Grass	2 GAL	CONTAINER	24" O.C.	WELL-ESTABLISHED IN CONTAINER
GROUN	NDCOV	ER					
324	LMB	Liriope muscari 'Big Blue'	Big Blue Lilyturf	1 GAL.	CONTAINER	15" O.C.	WELL-ESTABLISHED IN CONTAINER
359	LMM	Liriope muscari 'Monroe's White'	Monroe's White Lilyturf	1 GAL.	CONTAINER	15" O.C.	WELL-ESTABLISHED IN CONTAINER
1322	VM	Vinca minor	Periwinkle	FLAT	CONTAINER	3/SF	WELL-ESTABLISHED IN CONTAINER



SCALE: 1" = 10'-0"

KEY PLAN A1



SPONSOR

Westchester County, New York

Purchase College Learning Corporation 735 Anderson Hill Road Purchase, NY 10577-1402

PLANNER, CIVIL ENGINEER

DIVNEY • TUNG • SCHWALBE

Divney Tung Schwalbe, LLP One North Broadway White Plains, NY 10601

P: 914.428.0010 F: 914.428.0017

DEVELOPER LCS DEVELOPMENT 400 Locust Street, Suite 820 Des Moine, IA 50309

ARCHITECT HCM Design, Inc. 750 East Pratt Street Baltimore, MD 21202

LANDSCAPE ARCHITECT MKW and Associates, LLC 39 Park Avenue Rutherford, NJ 07070

SURVEYOR THE CHAZEN COMPANIES 21 Fox Street Poughkeepsie, NY 12601

WETLAND CONSULTANT WILLIAM KENNY ASSOCIATES LLC 195 Tunxis Hill Cutoff South Fairfield, CT 06825



NOTE: ALL SITE DESIGN CONCEPTS AND INFORMATION INDICATED OR REPRESENTED BY THIS DRAWING ARE OWNED BY AND ARE THE PROPERTY OF DIVNEY TUNG SCHWALBE, LLP. THIS DRAWING WAS CREATED AND DEVELOPED FOR USE ON, AND IN CONNECTION WITH, THE SPECIFIED PROJECT INDICATED HEREON AND SHALL NOT BE USED BY OR DISCLOSED TO ANY PERSON OR ENTITY WHATSOEVER WITHOUT THE WRITTEN PERMISSION OF DIVNEY

WRITTEN DIMENSIONS ON THIS DRAWING SHALL HAVE PRECEDENCE OVER SCALED MEASUREMENTS. CONTRACTOR SHALL VERIFY AND BE RESPONSIBLE FOR ALL DIMENSIONS AND CONDITIONS ON THE JOB AND THIS OFFICE MUST BE NOTIFIED OF ANY VARIATIONS FROM DIMENSIONS AND CONDITIONS SHOWN BY THESE DRAWINGS. LEGAL NOTICE: IT IS A VIOLATION OF ARTICLE 145 OF THE NEW

YORK STATE EDUCATION LAW FOR ANY PERSON TO ALTER THIS DOCUMENT IN ANY WAY EXCEPT AS PROVIDED IN SECTION 7209 (2), ARTICLE 145, NEW YORK STATE EDUCATION LAW.


© Copyright Divney Tung Schwalbe, LLP 2019

TUNG SCHWALBE, LLP.

SUN & MOON COURTYARD PLANTING ENLARGEMENT PLAN



SCALE: 1" = 300'

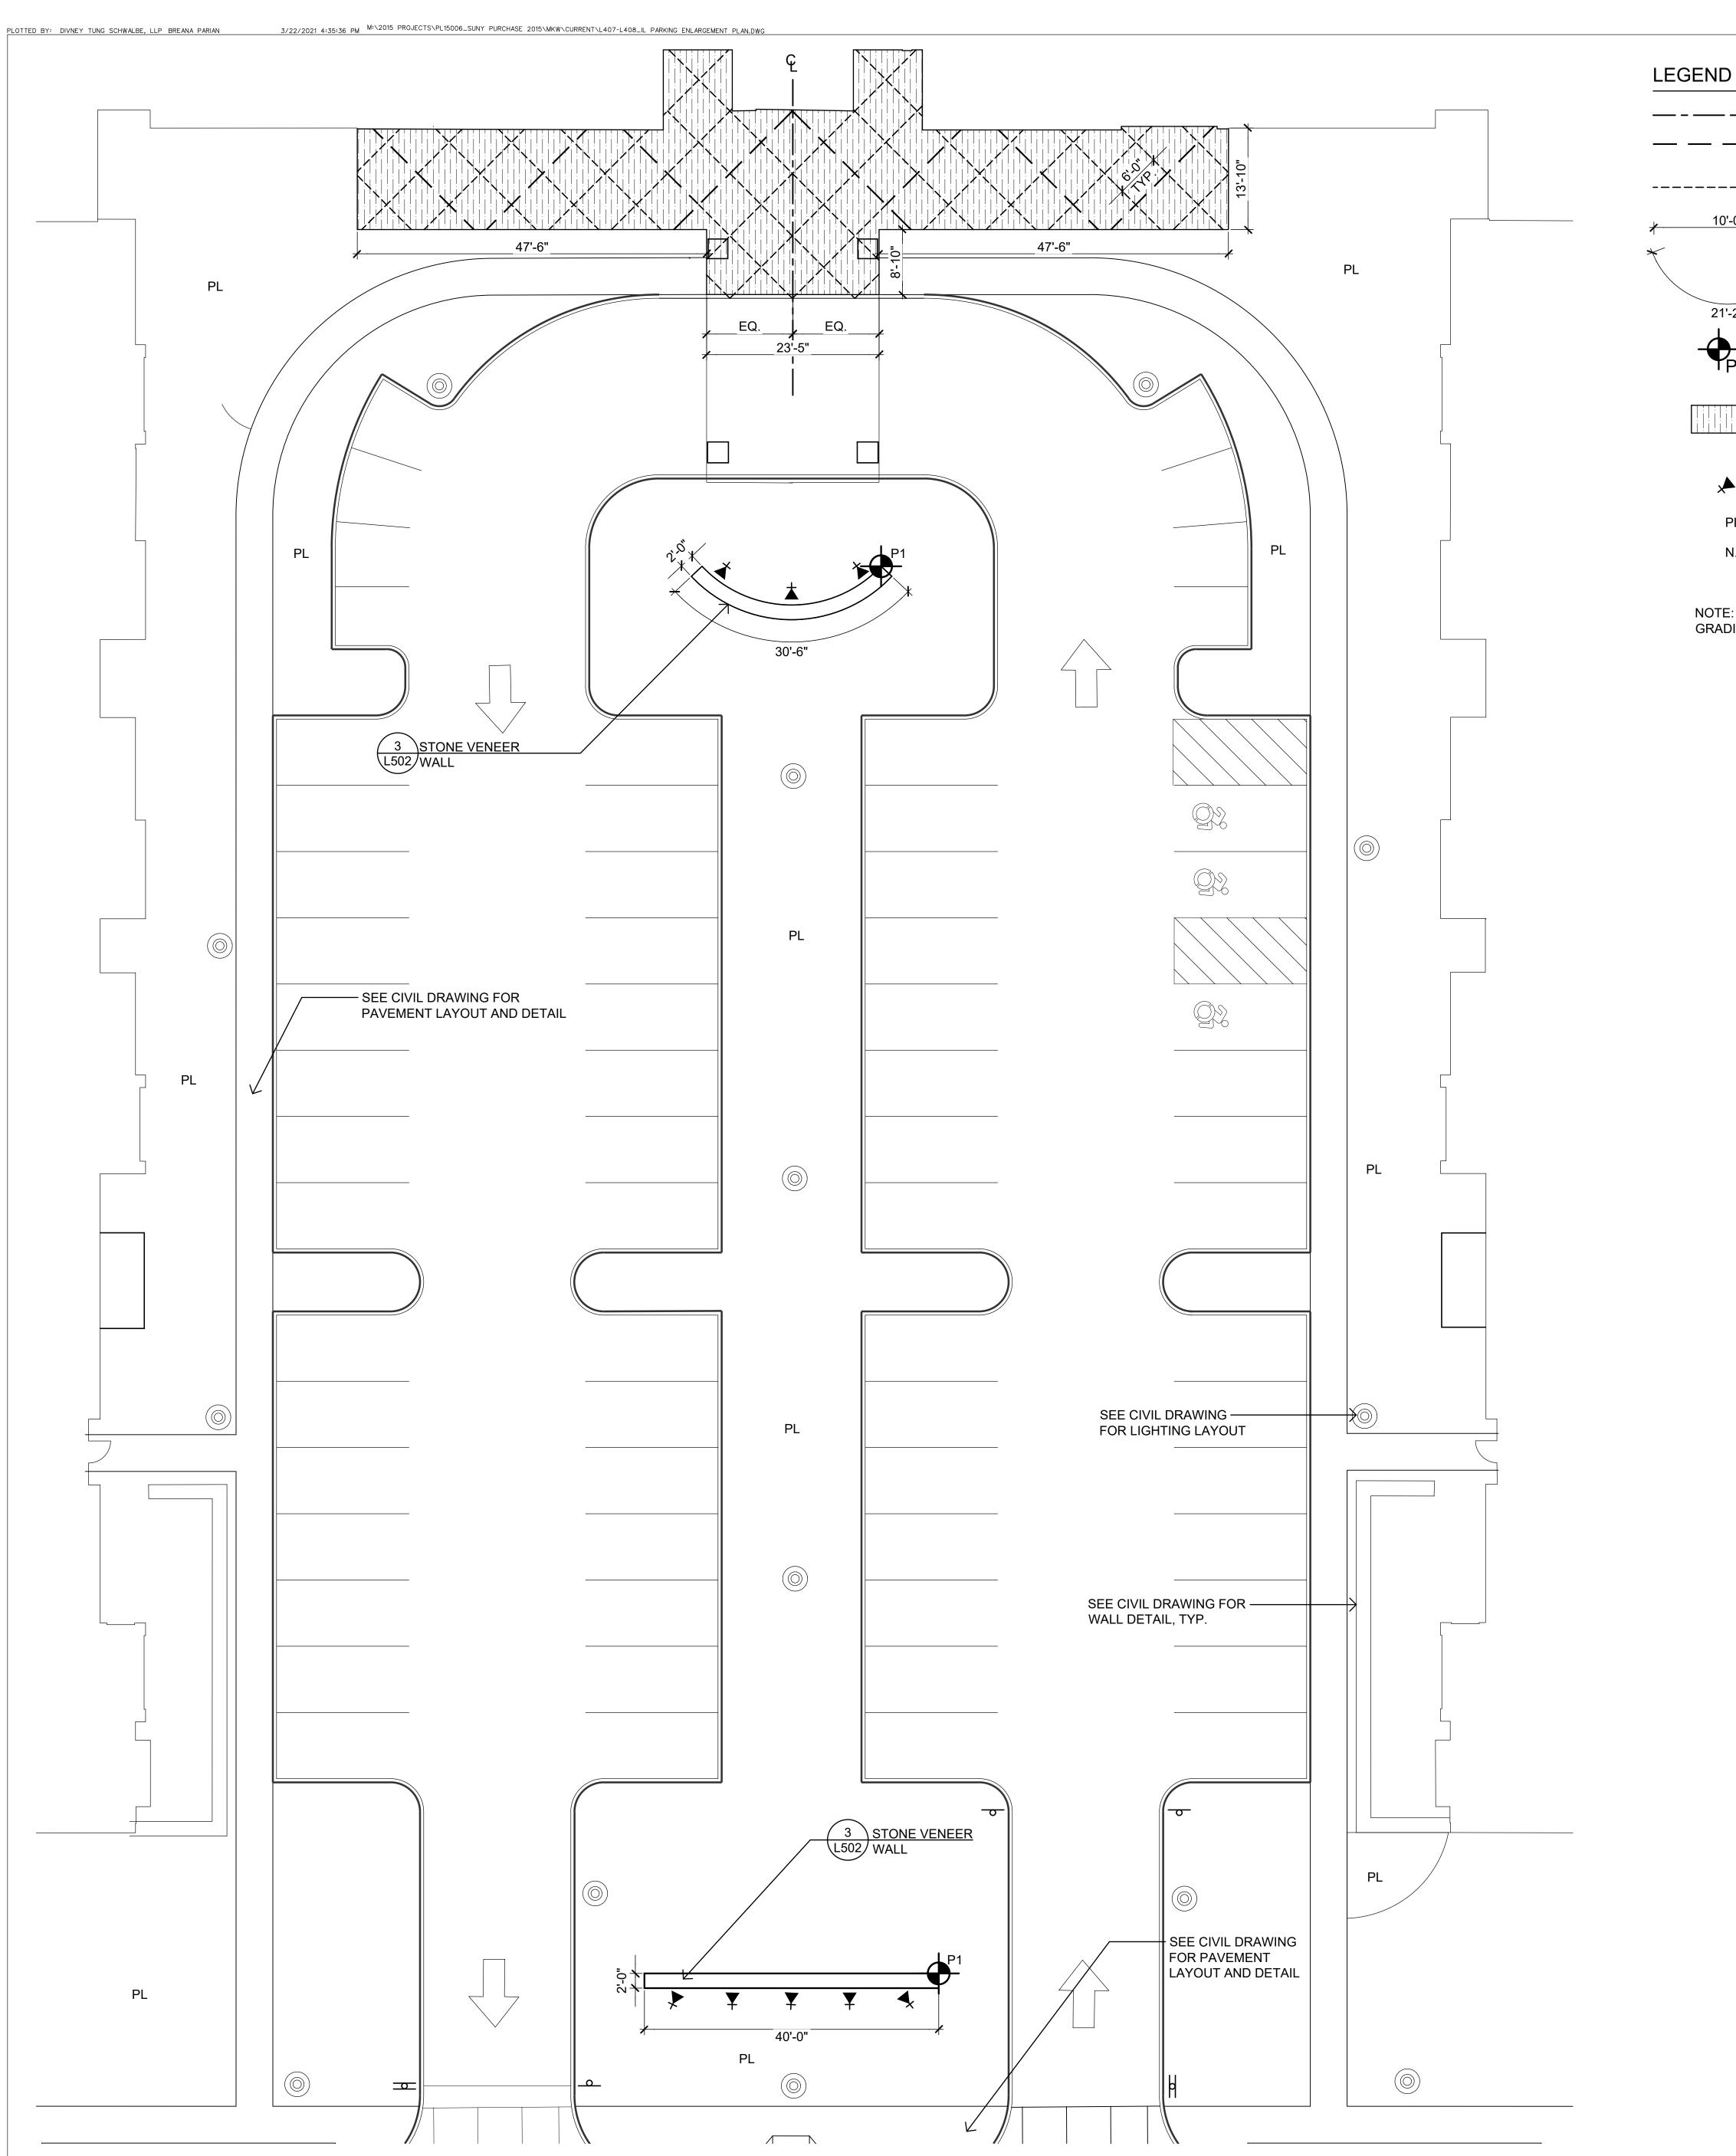




----- SCORE JOINT (SPACING
N.T.E 6'-0")

10'-0"

LINEAR DIMENSION

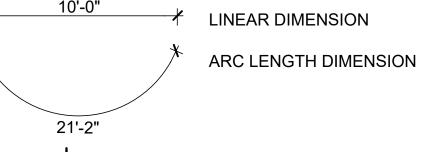

COLORED CONCRETE PAVEMENT COLOR: AUTUMN BEIGE

LOCATION POINT

8 ACCENT LIGHT

PL PLANTED AREA

N.T.E NOT TO EXCEED

NOTE: SEE CIVIL DRAWINGS FOR GRADING AND DRAINAGE LAYOUT

L(OCATION PO	INTS 💠
POINT	X	Y
7	221'-4"	-194'-4"
8	30'-1"	-202'-2"

X = HORIZONTAL DISTANCE, Y = VERTICAL DISTANCE;

NOTES: 1. LOCATION POINTS TAKEN FROM P.O.B 1 LOCATED ON 1/L405

2. LOCATION POINTS CONTINUED FROM 2/L405

KEY PLAN

PLANNER, CIVIL ENGINEER

Divney Tung Schwalbe, LLP One North Broadway White Plains, NY 10601

SPONSOR

P: 914.428.0010 F: 914.428.0017 DEVELOPER

LCS DEVELOPMENT 400 Locust Street, Suite 820 Des Moine, IA 50309

BROADVIEW

SENIOR LIVING

AT PURCHASE COLLEGE

Westchester County, New York

735 Anderson Hill Road

Purchase, NY 10577-1402

Purchase College Learning Corporation

DIVNEY • TUNG • SCHWALBE

ARCHITECT

HCM Design, Inc.
750 East Pratt Street

Baltimore, MD 21202

LANDSCAPE ARCHITECT
MKW and Associates, LLC
39 Park Avenue
Rutherford, NJ 07070

SURVEYOR

THE CHAZEN COMPANIES
21 Fox Street
Poughkeepsie, NY 12601

WETLAND CONSULTANT
WILLIAM KENNY ASSOCIATES LLC
195 Tunxis Hill Cutoff South
Fairfield, CT 06825



NOTE: ALL SITE DESIGN CONCEPTS AND INFORMATION INDICATED OR REPRESENTED BY THIS DRAWING ARE OWNED BY AND ARE THE PROPERTY OF DIVNEY TUNG SCHWALBE, LLP. THIS DRAWING WAS CREATED AND DEVELOPED FOR USE ON, AND IN CONNECTION WITH, THE SPECIFIED PROJECT INDICATED HEREON AND SHALL NOT BE USED BY OR DISCLOSED TO ANY PERSON OR ENTITY WHATSOEVER WITHOUT THE WRITTEN PERMISSION OF DIVNEY TUNG SCHWALBE, LLP.

WRITTEN DIMENSIONS ON THIS DRAWING SHALL HAVE PRECEDENCE OVER SCALED MEASUREMENTS. CONTRACTOR SHALL VERIFY AND BE RESPONSIBLE FOR ALL DIMENSIONS AND CONDITIONS ON THE JOB AND THIS OFFICE MUST BE NOTIFIED OF ANY VARIATIONS FROM DIMENSIONS AND CONDITIONS SHOWN BY THESE DRAWINGS.

LEGAL NOTICE: IT IS A VIOLATION OF ARTICLE 145 OF THE NEW YORK STATE EDUCATION LAW FOR ANY PERSON TO ALTER THIS DOCUMENT IN ANY WAY EXCEPT AS PROVIDED IN SECTION 7209 (2), ARTICLE 145, NEW YORK STATE EDUCATION LAW.

© Copyright Divney Tung Schwalbe, LLP 2019 All rights reserved.

SCALE: 1" = 10'-0"

SCALE: 1" = 300'

ISI	ISIONS				
	DATE	ISSUE			
_					
_					

INDEPENDENT LIVING
PARKING LOT
LAYOUT & MATERIALS
ENLARGEMENT PLAN




DRAWN BY:
MKW


PROJECT NO.
796

DRAWING NO.

DATE:
796

DRAWING NO.

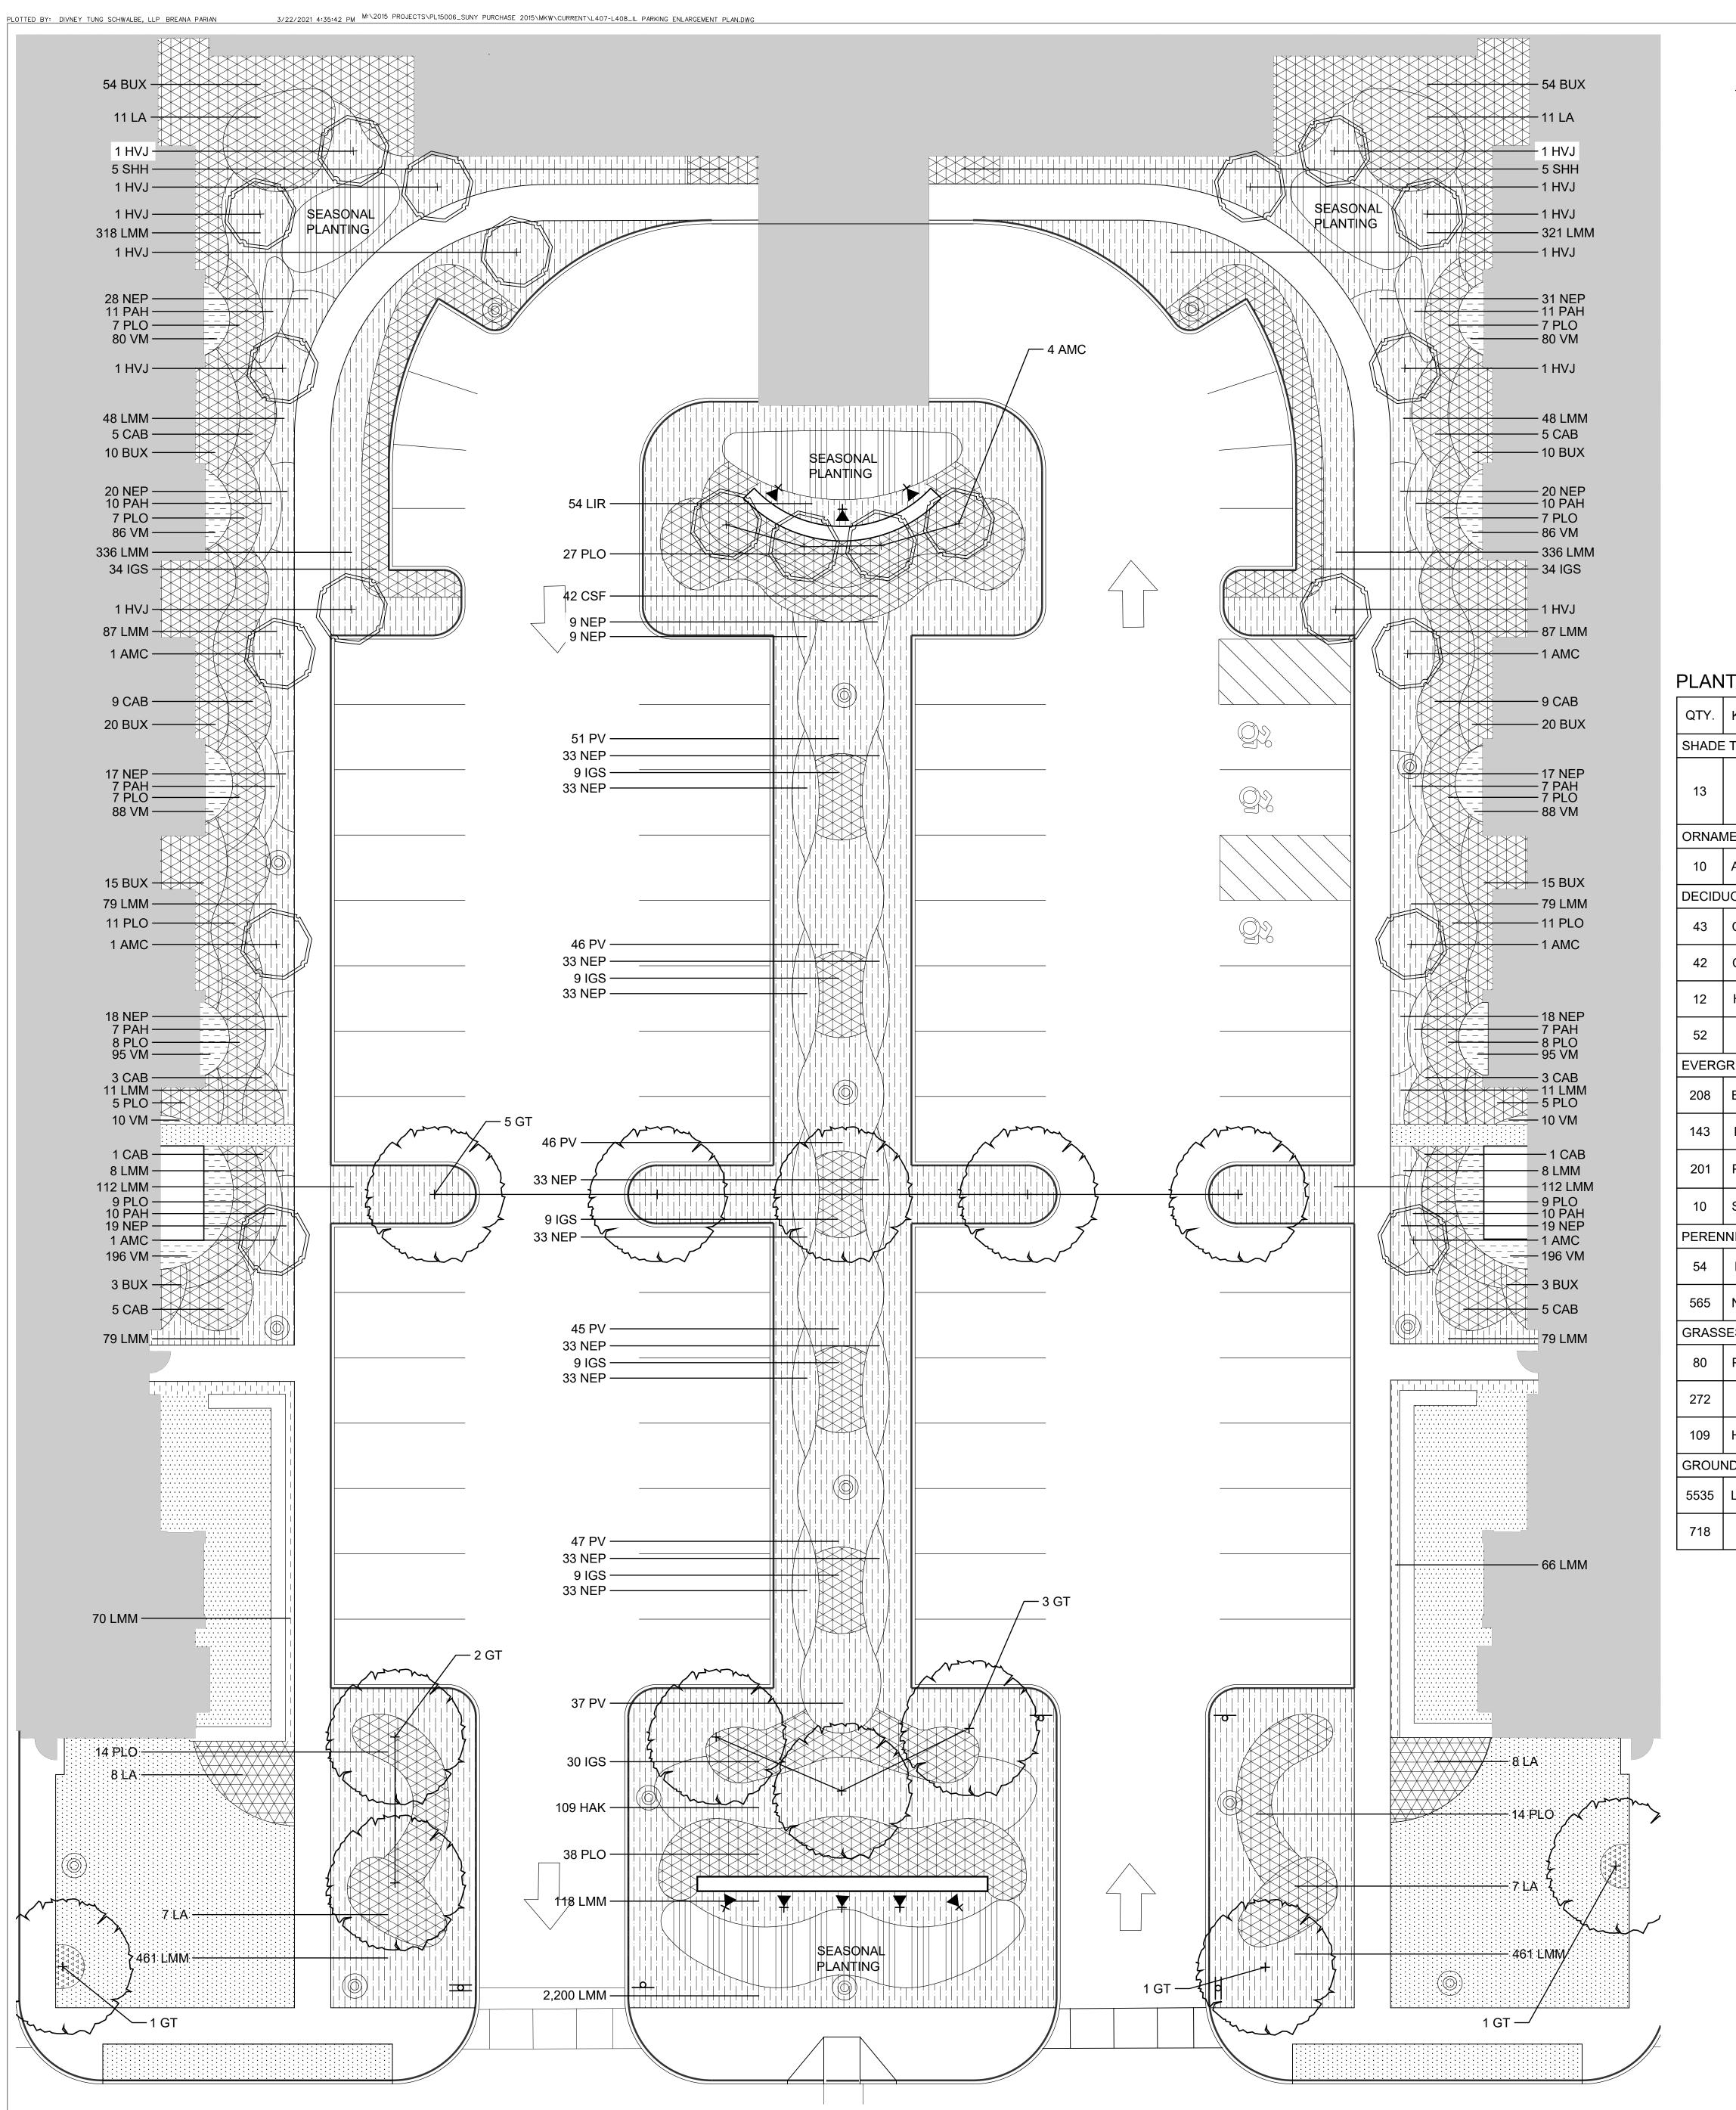


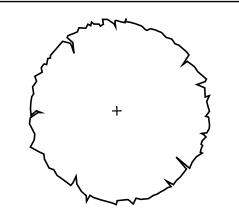





ORNAMENTAL TREE - PLANTING

    
MULCH - 2" DEPTH





 




 












SEASONAL PLANTING BY OTHERS

PLANTING SCHEDULE

BRANCHED 6-7' FROM GROUND, AVERAGE HEIGHT 11-12'. SPREA OF TOP 4-5'. MINIMUM OF 4 MAIN STEMS. WELL-ESTABLISHED WELL-ESTABLISHED
AN GROUND, AVERAGE HEIGHT 11-12'. SPREA OF TOP 4-5'. AN MINIMUM OF 4 MAIN STEMS. WELL-ESTABLISHED
AN GROUND, AVERAGE HEIGHT 11-12'. SPREA OF TOP 4-5'. AN MINIMUM OF 4 MAIN STEMS. WELL-ESTABLISHED
WELL-ESTABLISHED
WELL-ESTABLISHED
WELL-ESTABLISHED
VVELE-EOT/(BEIOTIEB
AN HEAVY, WELL-BRANCHED TOP
VIGOROUS, DENSE, SYMMETRICAL.
WELL-ESTABLISHED II CONTAINER.
WELL-ESTABLISHED I CONTAINER.
WELL-ESTABLISHED II CONTAINER.
WELL-ESTABLISHED II CONTAINER
WELL-ESTABLISHED II CONTAINER
WELL-ESTABLISHED II CONTAINER
WELL-ESTABLISHED II CONTAINER
WELL-ESTABLISHED II CONTAINER



SCALE: 1" = 300'

KEY PLAN A1



Westchester County, New York

SPONSOR

Purchase College Learning Corporation 735 Anderson Hill Road Purchase, NY 10577-1402

PLANNER, CIVIL ENGINEER

DIVNEY • TUNG • SCHWALBE

Divney Tung Schwalbe, LLP One North Broadway White Plains, NY 10601 P: 914.428.0010 F: 914.428.0017

DEVELOPER LCS DEVELOPMENT 400 Locust Street, Suite 820

Des Moine, IA 50309 ARCHITECT

HCM Design, Inc. 750 East Pratt Street Baltimore, MD 21202

LANDSCAPE ARCHITECT MKW and Associates, LLC 39 Park Avenue Rutherford, NJ 07070

SURVEYOR THE CHAZEN COMPANIES 21 Fox Street

Poughkeepsie, NY 12601

WETLAND CONSULTANT WILLIAM KENNY ASSOCIATES LLC 195 Tunxis Hill Cutoff South Fairfield, CT 06825



NOTE: ALL SITE DESIGN CONCEPTS AND INFORMATION INDICATED OR REPRESENTED BY THIS DRAWING ARE OWNED BY AND ARE THE PROPERTY OF DIVNEY TUNG SCHWALBE, LLP. THIS DRAWING WAS CREATED AND DEVELOPED FOR USE ON, AND IN CONNECTION WITH, THE SPECIFIED PROJECT INDICATED HEREON AND SHALL NOT BE USED BY OR DISCLOSED TO ANY PERSON OR ENTITY WHATSOEVER WITHOUT THE WRITTEN PERMISSION OF DIVNEY TUNG SCHWALBE, LLP.

WRITTEN DIMENSIONS ON THIS DRAWING SHALL HAVE PRECEDENCE OVER SCALED MEASUREMENTS. CONTRACTOR SHALL VERIFY AND BE RESPONSIBLE FOR ALL DIMENSIONS AND CONDITIONS ON THE JOB AND THIS OFFICE MUST BE NOTIFIED OF ANY VARIATIONS FROM DIMENSIONS AND CONDITIONS SHOWN BY


THESE DRAWINGS. LEGAL NOTICE: IT IS A VIOLATION OF ARTICLE 145 OF THE NEW YORK STATE EDUCATION LAW FOR ANY PERSON TO ALTER THIS DOCUMENT IN ANY WAY EXCEPT AS PROVIDED IN SECTION 7209 (2), ARTICLE 145, NEW YORK STATE EDUCATION LAW.


© Copyright Divney Tung Schwalbe, LLP 2019 All rights reserved.

REVISI	REVISIONS					
NO.	DATE	ISSUE				

INDEPENDENT LIVING PARKING LOT PLANTING **ENLARGEMENT PLAN**



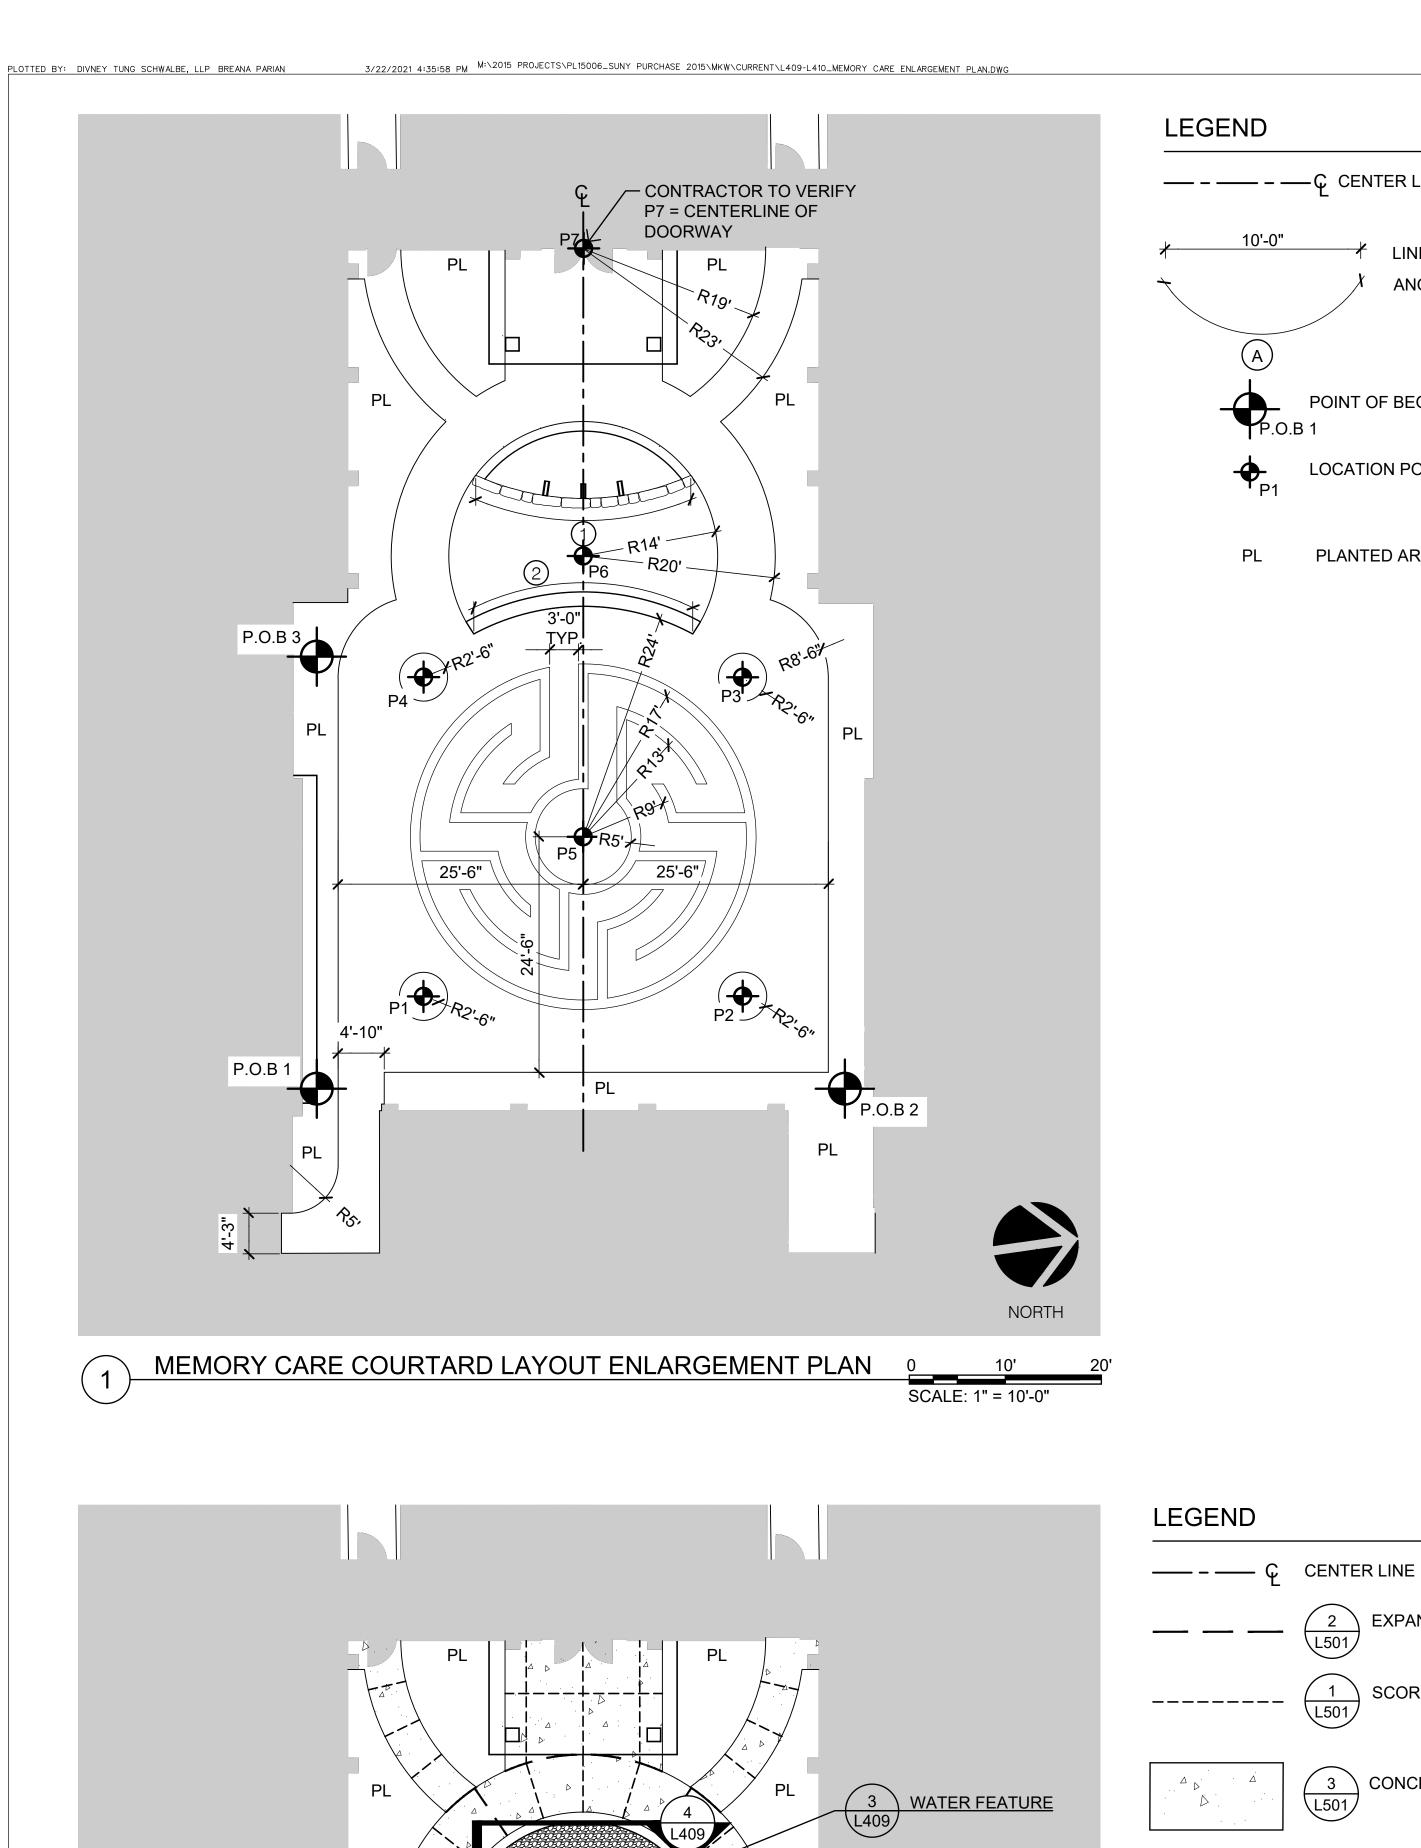

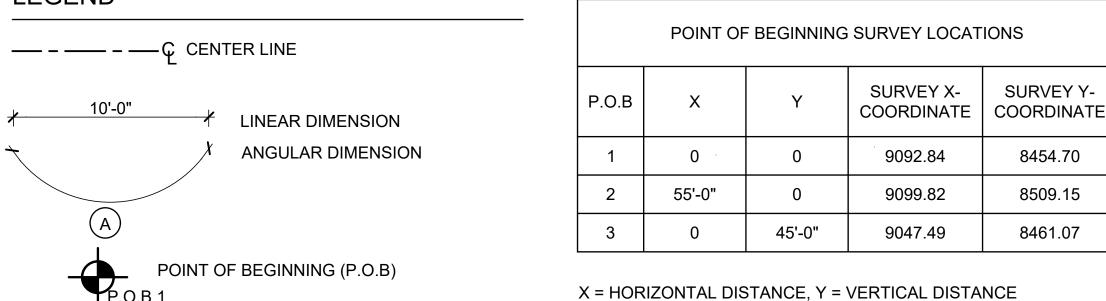

LOCATION POINT

PLANTED AREA

EXPANSION JOINT

CONCRETE PAVEMENT


GRANITE SETT

LOCATION POINTS -				
POINT	Х	Y		
1	11'-1"	9'-7"		
2	44'-4"	9'-7"		
3	44'-4"	42'-10"		
4	11'-2"	42'-10"		
5	27'-9"	26'-3"		
6	27'-9"	55'-6"		
7	27'-9"	87'-6"		


4	11-2	42-10
5	27'-9"	26'-3"
6	27'-9"	55'-6"
7	27'-9"	87'-6"

X = HORIZONTAL DISTANCE, Y = VERTICAL DISTANCE; TAKEN FROM P.O.B. 1


ARC SCHEDULE #			
ARC	RADIUS	ANGLE	LENGTH
1	27'-0"	49°	23'-1"
2	24'-0"	57°	23'-9"

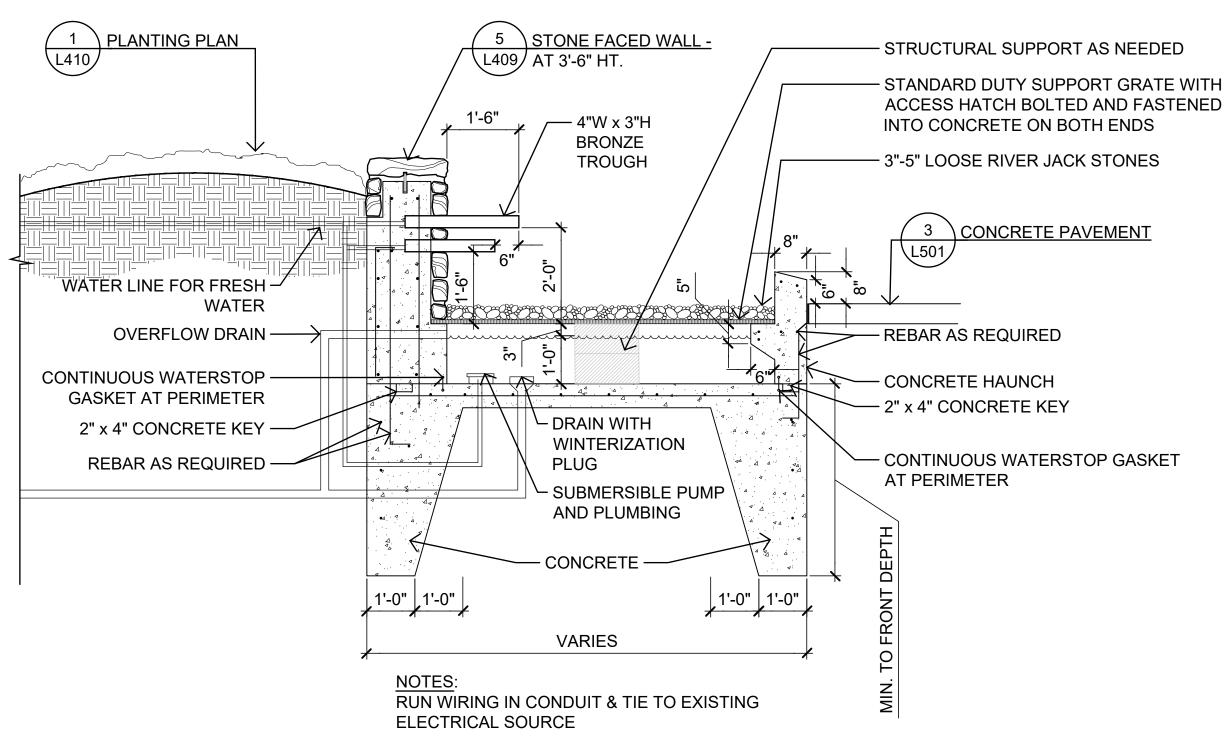

WATER FEATURE SCALE: 1/2" = 1'-0" 1. ALL BLOCKS SHALL HAVE HAND-TIGHT JOINTS, WITH A MAXIMUM GAP OF 3/8" - 1/2" BETWEEN EACH BLOCK. 2. ALL STONE BLOCKS SHALL BE CUT RADIALLY, WITH MAX 3/8" - 1/2" JOINT. LINEAR DIMENSION LINEAR DIMENSION

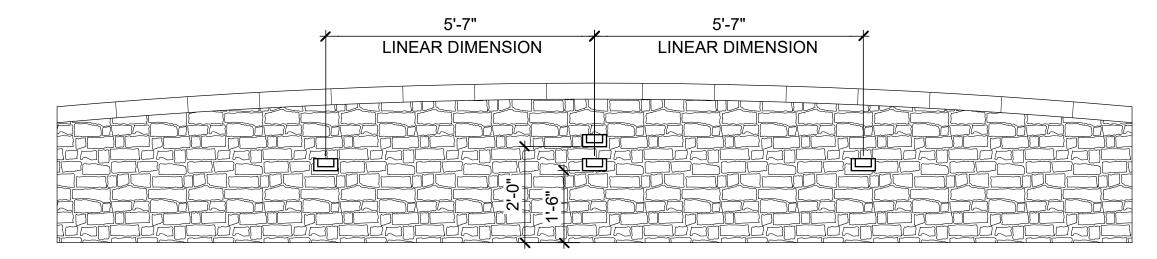



STONE FACED WALL ELEVATION SCALE: 1/2" = 1'-0"

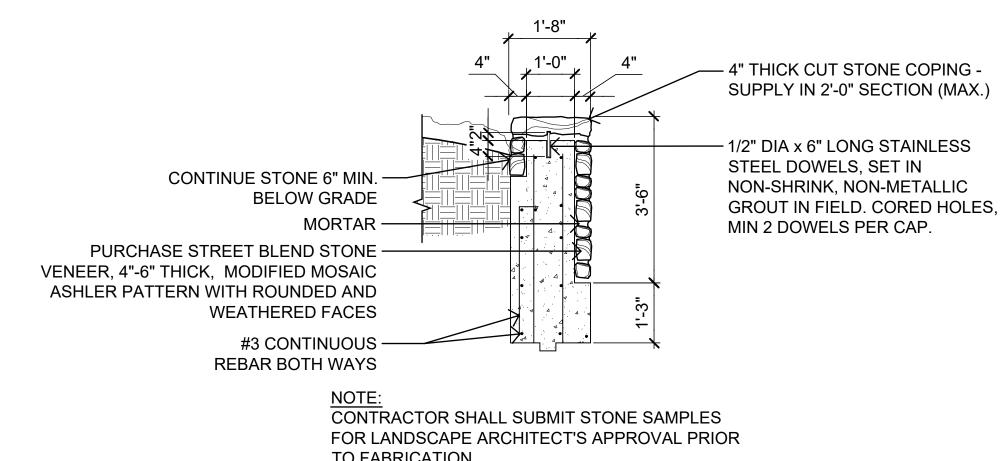

TO FABRICATION

 STONE FACED WALL 3'-6" HT.



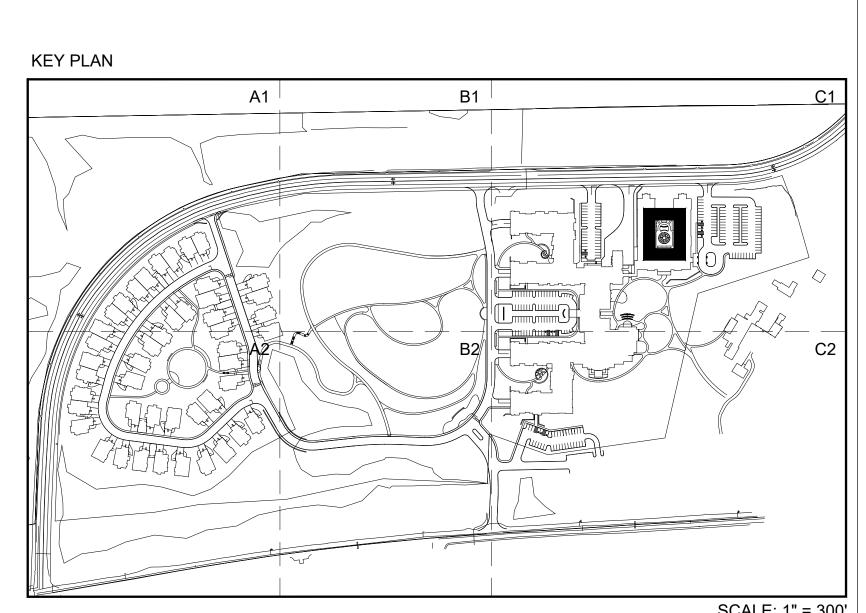



<u>SPONSOR</u> Purchase College Learning Corporation 735 Anderson Hill Road

Purchase, NY 10577-1402

PLANNER, CIVIL ENGINEER DIVNEY • TUNG • SCHWALBE

Divney Tung Schwalbe, LLP One North Broadway White Plains, NY 10601 P: 914.428.0010

F: 914.428.0017 DEVELOPER

LCS DEVELOPMENT 400 Locust Street, Suite 820

Des Moine, IA 50309 ARCHITECT

HCM Design, Inc. 750 East Pratt Street Baltimore, MD 21202

LANDSCAPE ARCHITECT MKW and Associates, LLC 39 Park Avenue

Rutherford, NJ 07070

SURVEYOR THE CHAZEN COMPANIES 21 Fox Street

Poughkeepsie, NY 12601

WETLAND CONSULTANT WILLIAM KENNY ASSOCIATES LLC 195 Tunxis Hill Cutoff South Fairfield, CT 06825



NOTE: ALL SITE DESIGN CONCEPTS AND INFORMATION INDICATED OR REPRESENTED BY THIS DRAWING ARE OWNED BY AND ARE THE PROPERTY OF DIVNEY TUNG SCHWALBE, LLP. THIS DRAWING WAS CREATED AND DEVELOPED FOR USE ON, AND IN CONNECTION WITH, THE SPECIFIED PROJECT INDICATED HEREON AND SHALL NOT BE USED BY OR DISCLOSED TO ANY PERSON OR ENTITY WHATSOEVER WITHOUT THE WRITTEN PERMISSION OF DIVNEY TUNG SCHWALBE, LLP.


WRITTEN DIMENSIONS ON THIS DRAWING SHALL HAVE PRECEDENCE OVER SCALED MEASUREMENTS. CONTRACTOR SHALL VERIFY AND BE RESPONSIBLE FOR ALL DIMENSIONS AND CONDITIONS ON THE JOB AND THIS OFFICE MUST BE NOTIFIED OF ANY VARIATIONS FROM DIMENSIONS AND CONDITIONS SHOWN BY THESE DRAWINGS. LEGAL NOTICE: IT IS A VIOLATION OF ARTICLE 145 OF THE NEW YORK STATE EDUCATION LAW FOR ANY PERSON TO ALTER THIS

DOCUMENT IN ANY WAY EXCEPT AS PROVIDED IN SECTION 7209 (2), ARTICLE 145, NEW YORK STATE EDUCATION LAW.

© Copyright Divney Tung Schwalbe, LLP 2019 All rights reserved.


NO. DATE ISSUE

MEMORY CARE LAYOUT & MATERIALS ENLARGEMENT PLAN

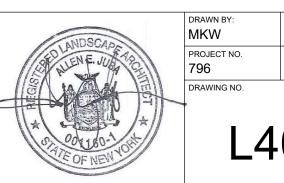

MEMORY CARE COURTYARD MATERIALS ENLARGEMENT PLAN

 
5 STONE VENEER WALL



6 GRANITE SETT

 PL

SCALE: 1" = 300'

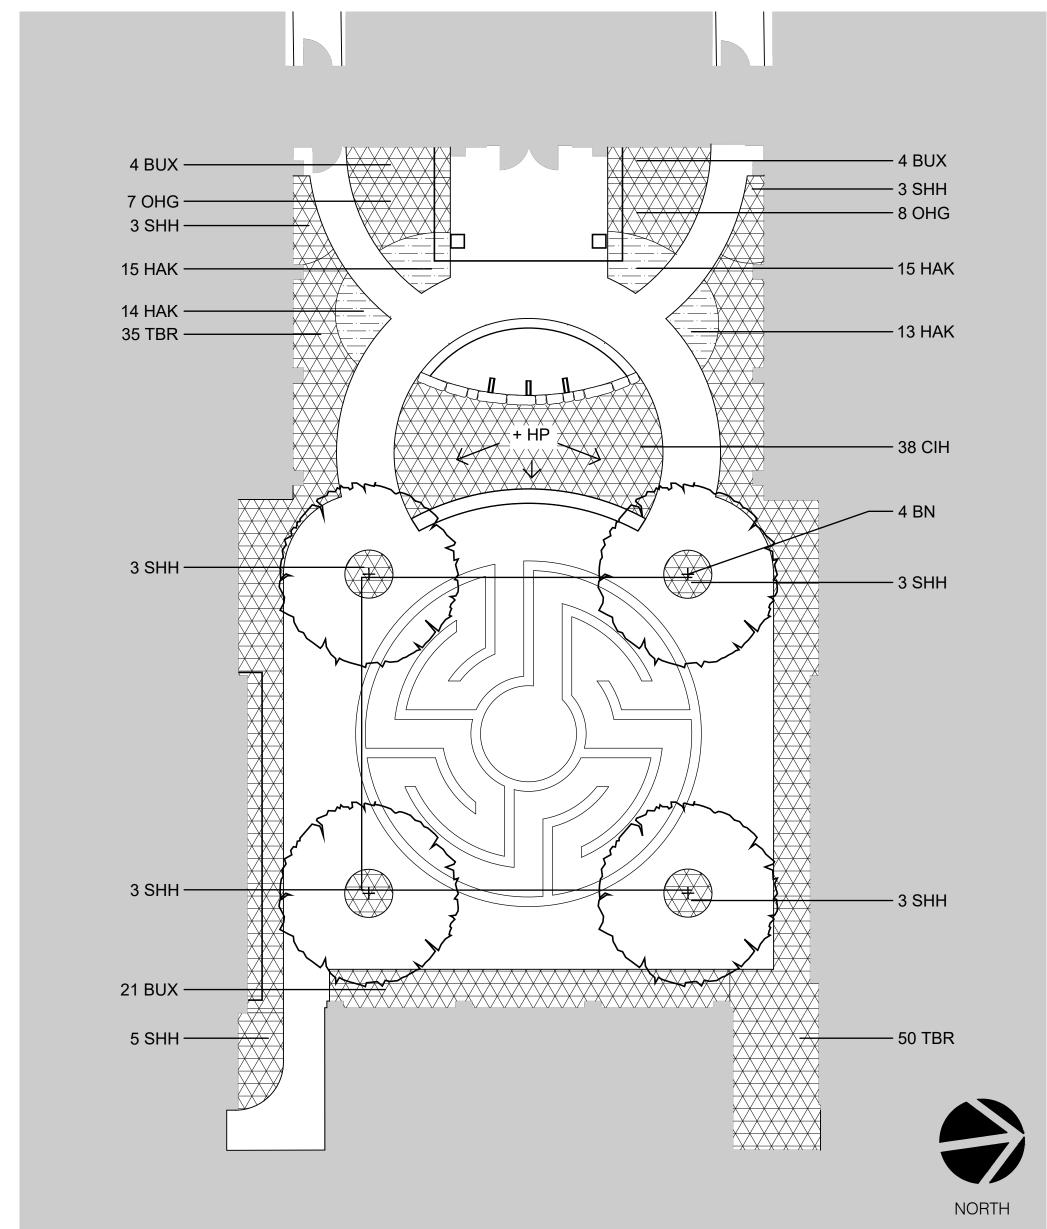



3/22/2021 4:36:07 PM M:\2015 PROJECTS\PL15006_SUNY PURCHASE 2015\MKW\CURRENT\L409-L410_MEMORY CARE ENLARGEMENT PLAN.DWG

PLOTTED BY: DIVNEY TUNG SCHWALBE, LLP BREANA PARIAN

+ 1 SHADE TREE PLANTING 4 SHRUB PLANTING 6 PERENNIALS, GRASSES AND GROUNDCOVER PLANTING

QTY	KEY	BOTANICAL NAME	COMMON NAME	SIZE	ROOT	SPACING	COMMENTS
SHADE	TREE	S	1			<u> </u>	
4	BN	Betula nigra 'Dura Heat'	Dura Heat River Birch	8' - 10' HT.	B&B	AS PER PLAN	CLUMP FORM HAVING 3 OR MORE MAIN STEMS ARISING FROM THE MAIN TRUNK, NOT MORE THAN 6" FROM GROUND LEVEL.
EVERG	BREEN	SHRUBS					
29	BUX	Buxus semipervirens 'Suffruticosa'	Compact Boxwood	12" - 15" HT.	CONTAINER	36" O.C.	VIGOROUS, DENSE, SYMMETRICAL.
15	OHG	Osmanthus heterophyllus 'Goshiki'	Goshiki False Holly	15" - 18" HT.	CONTAINER	42" O.C.	VIGOROUS, DENSE, SYMMETRICAL.
23	SHH	Sarcococca hookeriana var. humilis	Himalayan Sweet Box	12" - 15" HT.	CONTAINER	36" O.C.	VIGOROUS, DENSE, SYMMETRICAL.
85	TBR	Taxus baccata 'Repandens'	Spreading English Yew	12" - 15" HT.	CONTAINER	42" O.C.	VIGOROUS, DENSE, SYMMETRICAL.
DECID	UOUS S	SHRUBS	•				
38	CIH	Cornus alba 'Ivory Halo'	Variegated Redtwig Dogwood	12" - 15" HT.	B&B OR CONTAINER	36" O.C.	VIGOROUS, DENSE, SYMMETRICAL.
GRASS	SES	•	•		•		
57	HAK	Hakonechloa macra	Japanese Forest Grass	1 GAL.	CONTAINER	18" O.C.	WELL-ESTABLISHED IN CONTAINER

 

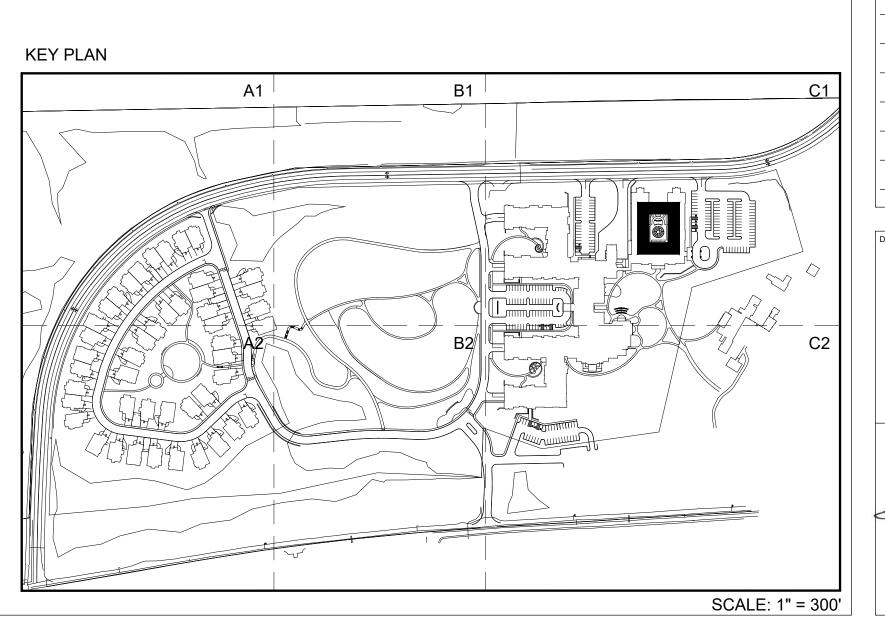

BROADVIEW

SENIOR LIVING

AT PURCHASE COLLEGE

Westchester County, New York

SPONSOR

Purchase College Learning Corporation

735 Anderson Hill Road Purchase, NY 10577-1402

PLANNER, CIVIL ENGINEER

DIVNEY • TUNG • SCHWALBE Intelligent Land U

Divney Tung Schwalbe, LLP One North Broadway White Plains, NY 10601

P: 914.428.0010 F: 914.428.0017

DEVELOPER

LCS DEVELOPMENT
400 Locust Street, Suite 820

Des Moine, IA 50309

ARCHITECT
HCM Design, Inc.

HCM Design, Inc. 750 East Pratt Street Baltimore, MD 21202

LANDSCAPE ARCHITECT
MKW and Associates, LLC

MKW and Associates, LLC 39 Park Avenue Rutherford, NJ 07070

SURVEYOR

THE CHAZEN COMPANIES
21 Fox Street
Poughkeepsie, NY 12601

WETLAND CONSULTANT
WILLIAM KENNY ASSOCIATES LLC
195 Tunxis Hill Cutoff South
Fairfield, CT 06825



NOTE: ALL SITE DESIGN CONCEPTS AND INFORMATION INDICATED OR REPRESENTED BY THIS DRAWING ARE OWNED BY AND ARE THE PROPERTY OF DIVNEY TUNG SCHWALBE, LLP. THIS DRAWING WAS CREATED AND DEVELOPED FOR USE ON, AND IN CONNECTION WITH, THE SPECIFIED PROJECT INDICATED HEREON AND SHALL NOT BE USED BY OR DISCLOSED TO ANY PERSON OR ENTITY WHATSOEVER WITHOUT THE WRITTEN PERMISSION OF DIVNEY TUNG SCHWALBE, LLP.


WRITTEN DIMENSIONS ON THIS DRAWING SHALL HAVE PRECEDENCE OVER SCALED MEASUREMENTS. CONTRACTOR SHALL VERIFY AND BE RESPONSIBLE FOR ALL DIMENSIONS AND CONDITIONS ON THE JOB AND THIS OFFICE MUST BE NOTIFIED OF ANY VARIATIONS FROM DIMENSIONS AND CONDITIONS SHOWN BY THESE DRAWINGS.


LEGAL NOTICE: IT IS A VIOLATION OF ARTICLE 145 OF THE NEW YORK STATE EDUCATION LAW FOR ANY PERSON TO ALTER THIS DOCUMENT IN ANY WAY EXCEPT AS PROVIDED IN SECTION 7209 (2), ARTICLE 145, NEW YORK STATE EDUCATION LAW.

© Copyright Divney Tung Schwalbe, LLP 2019 All rights reserved.

NO. DATE ISSUE

MEMORY CARE
PLANTING
ENLARGEMENT PLAN

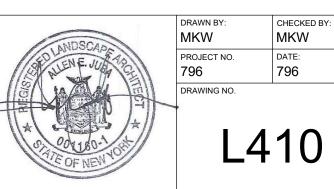

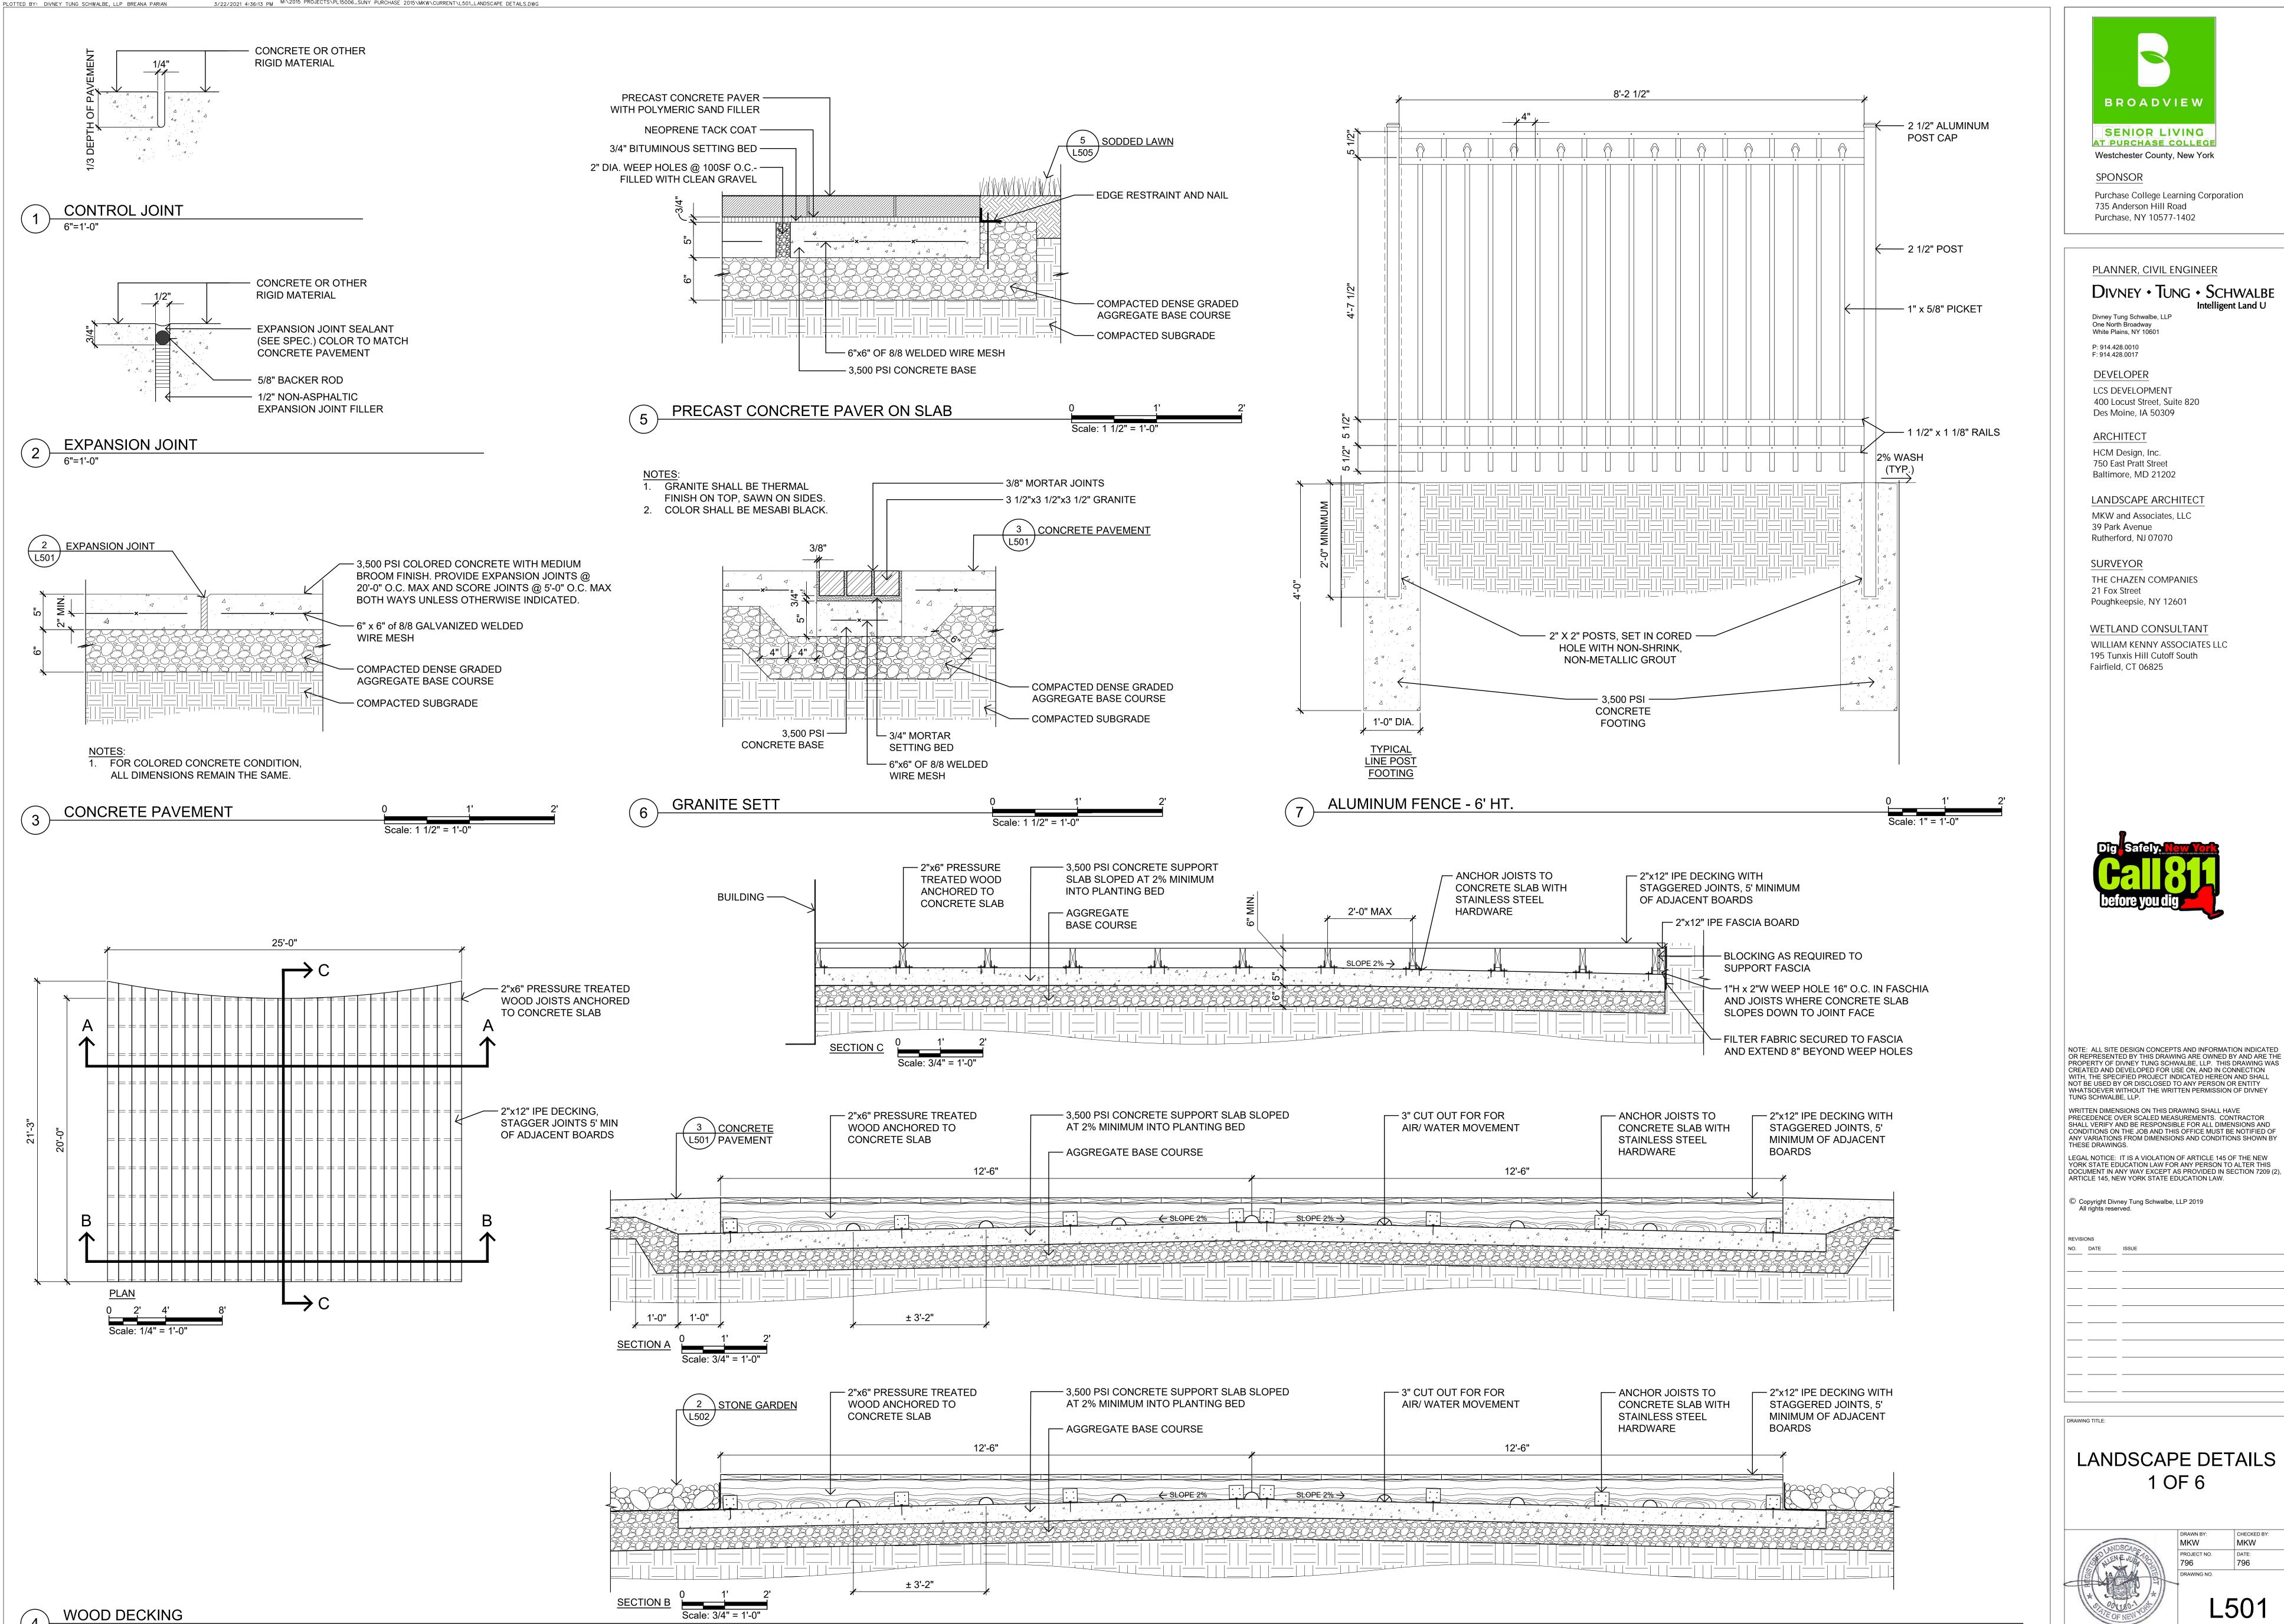


3/22/2021 4:36:13 PM M:\2015 PROJECTS\PL15006_SUNY PURCHASE 2015\MKW\CURRENT\L501_LANDSCAPE DETAILS.DWC

WOOD DECKING

AS SHOWN




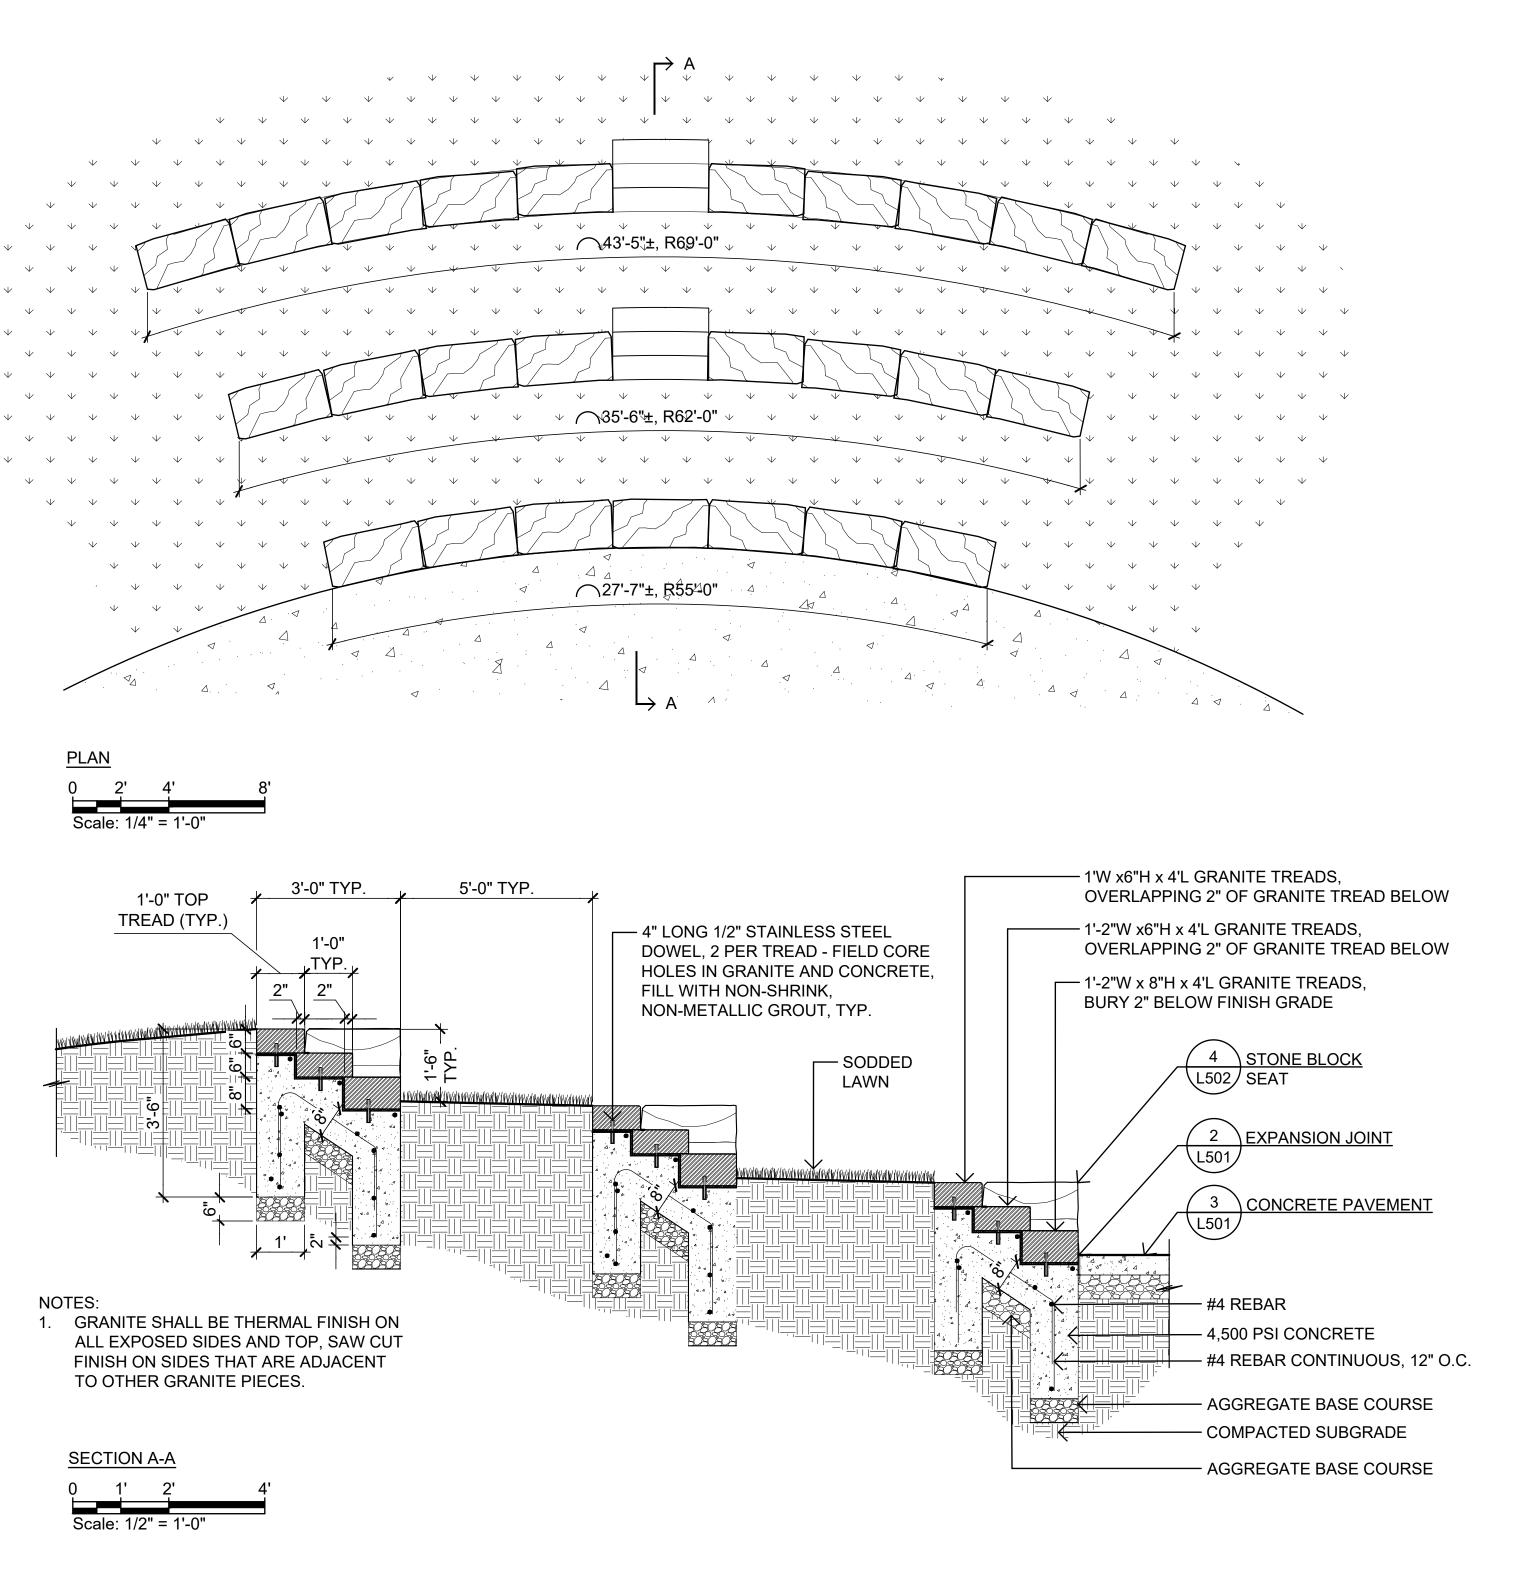


3/22/2021 4:36:23 PM M:\2015 PROJECTS\PL15006_SUNY PURCHASE 2015\MKW\CURRENT\L502_LANDSCAPE DETAILS.DW




PLOTTED BY: DIVNEY TUNG SCHWALBE, LLP BREANA PARIAN

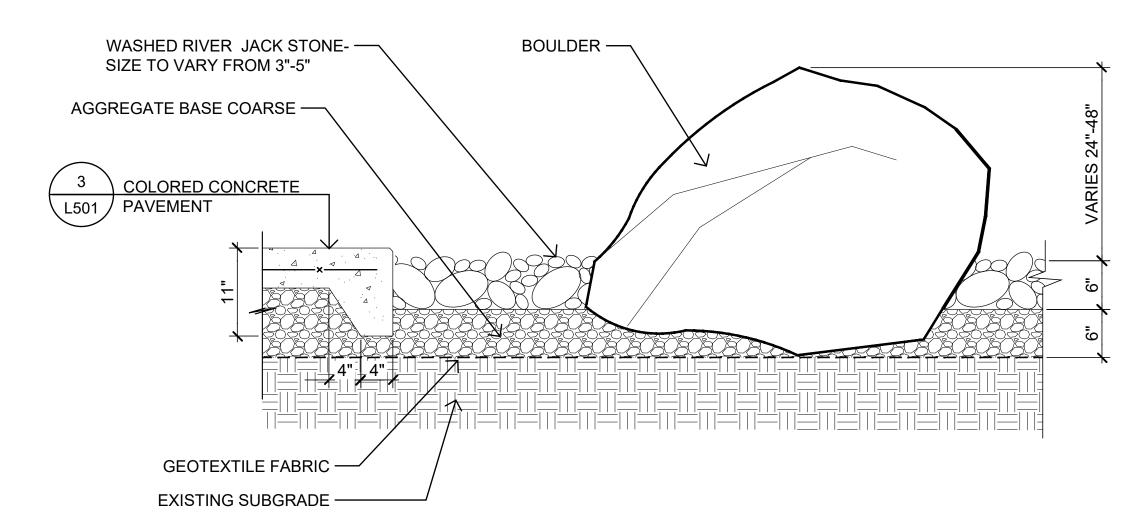


STONE GARDEN

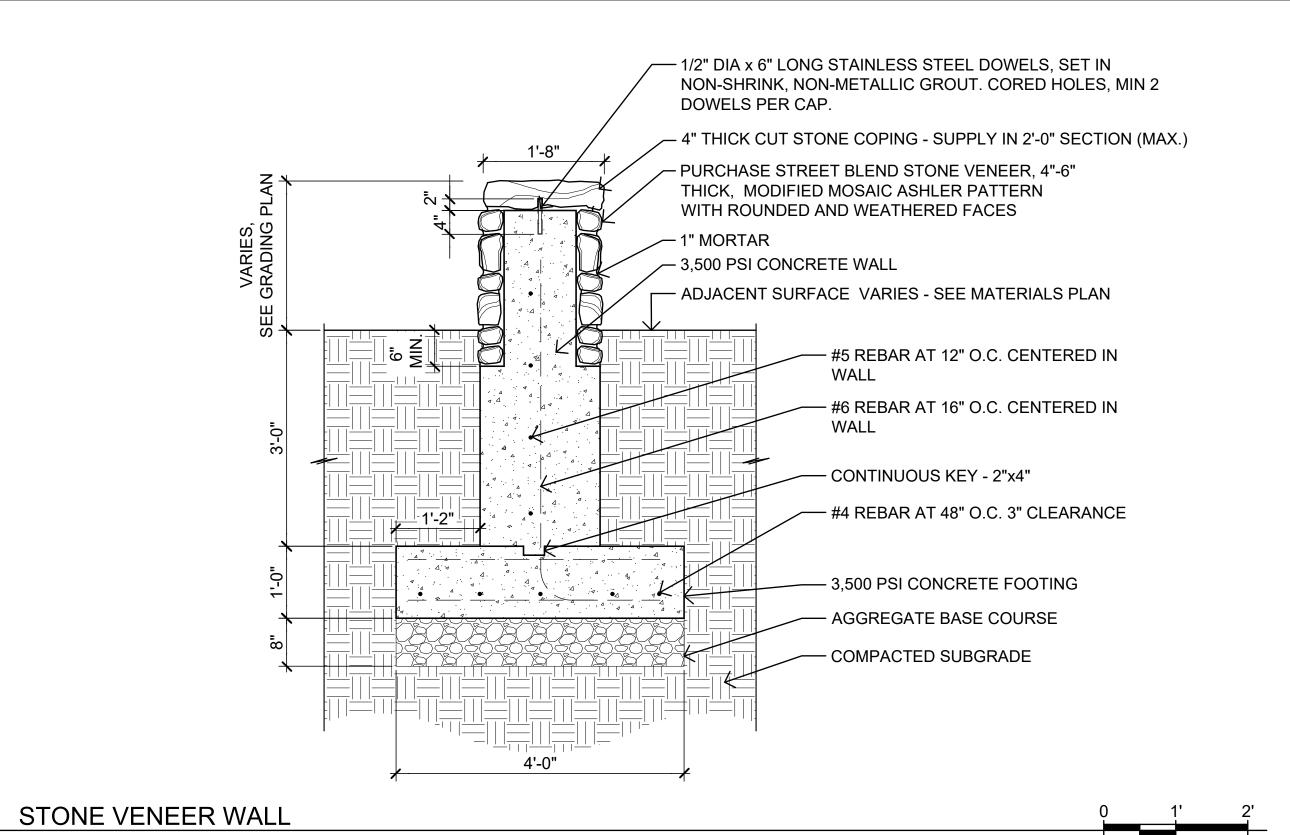


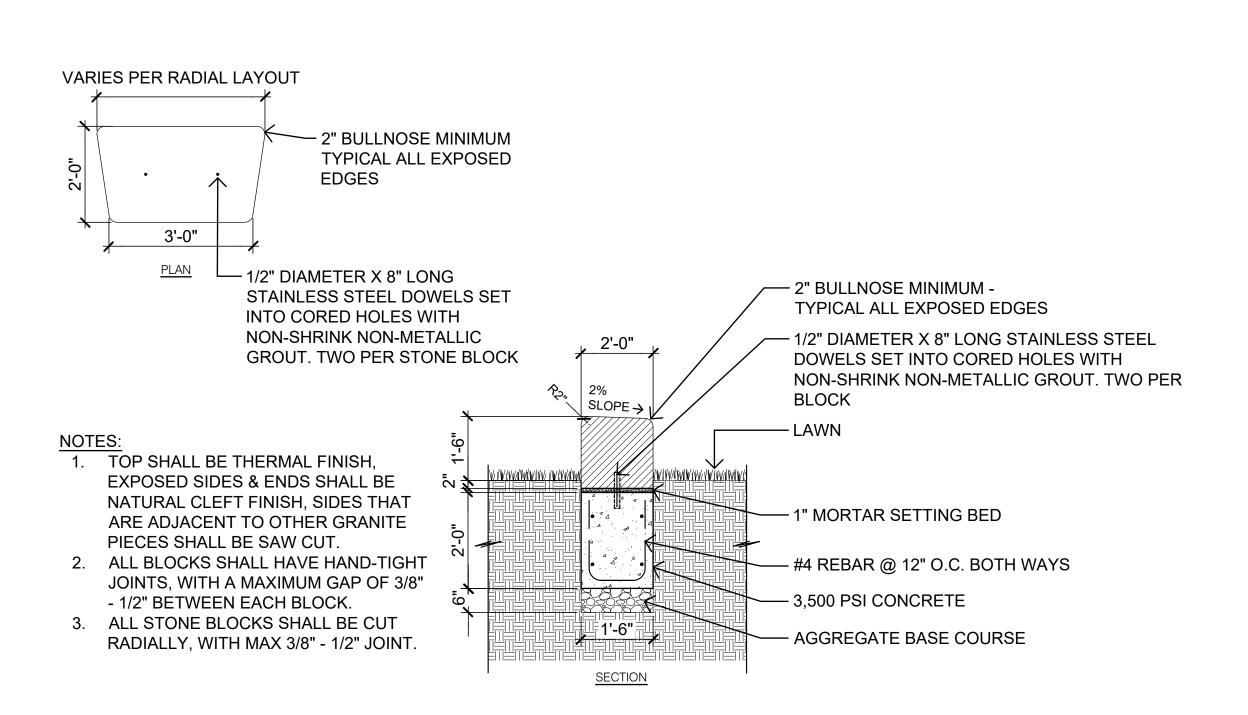



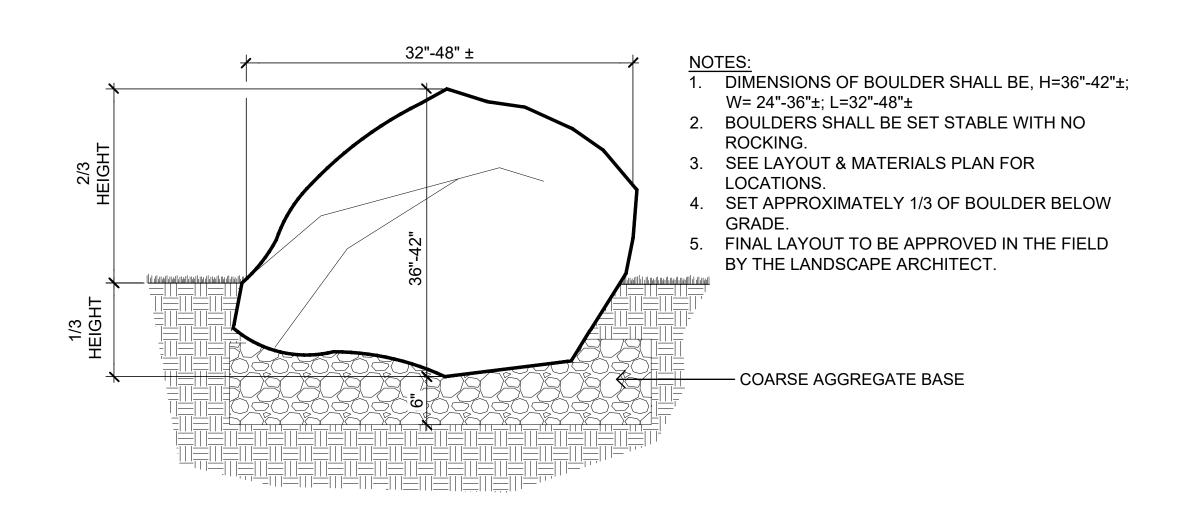



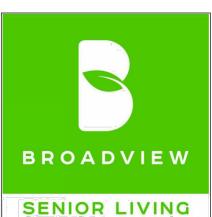

AT PURCHASE COLLEGE
Westchester County, New York

<u>SPONSOR</u>

Purchase College Learning Corporation 735 Anderson Hill Road Purchase, NY 10577-1402

PLANNER, CIVIL ENGINEER

DIVNEY • TUNG • SCHWALBE

Divney Tung Schwalbe, LLP One North Broadway White Plains, NY 10601

White Plains, NY 10601
P: 914.428.0010

DEVELOPER

F: 914.428.0017

LCS DEVELOPMENT 400 Locust Street, Suite 820

Des Moine, IA 50309

ARCHITECT

HCM Design, Inc. 750 East Pratt Street

Baltimore, MD 21202

LANDSCAPE ARCHITECT

MKW and Associates, LLC 39 Park Avenue Rutherford, NJ 07070

SURVEYOR

THE CHAZEN COMPANIES 21 Fox Street

Poughkeepsie, NY 12601

WETLAND CONSULTANT
WILLIAM KENNY ASSOCIATES LLC
195 Tunxis Hill Cutoff South
Fairfield, CT 06825



NOTE: ALL SITE DESIGN CONCEPTS AND INFORMATION INDICATED OR REPRESENTED BY THIS DRAWING ARE OWNED BY AND ARE THE PROPERTY OF DIVNEY TUNG SCHWALBE, LLP. THIS DRAWING WAS CREATED AND DEVELOPED FOR USE ON, AND IN CONNECTION WITH, THE SPECIFIED PROJECT INDICATED HEREON AND SHALL NOT BE USED BY OR DISCLOSED TO ANY PERSON OR ENTITY WHATSOEVER WITHOUT THE WRITTEN PERMISSION OF DIVNEY TUNG SCHWALBE, LLP.

WRITTEN DIMENSIONS ON THIS DRAWING SHALL HAVE PRECEDENCE OVER SCALED MEASUREMENTS. CONTRACTOR SHALL VERIFY AND BE RESPONSIBLE FOR ALL DIMENSIONS AND CONDITIONS ON THE JOB AND THIS OFFICE MUST BE NOTIFIED OF ANY VARIATIONS FROM DIMENSIONS AND CONDITIONS SHOWN BY THESE DRAWINGS.

LEGAL NOTICE: IT IS A VIOLATION OF ARTICLE 145 OF THE NEW YORK STATE EDUCATION LAW FOR ANY PERSON TO ALTER THIS

DOCUMENT IN ANY WAY EXCEPT AS PROVIDED IN SECTION 7209 (2),

ARTICLE 145, NEW YORK STATE EDUCATION LAW.

	© Copyright Divney Tung Schwalbe, LLP 2019 All rights reserved.

NO. DATE ISSUE

DRAWING TITLE

REVISIONS

LANDSCAPE DETAILS 2 OF 6



DRAWN BY:

MKW

PROJECT NO.

796

DRAWING NO.

CHECKED BY:

MKW


PROJECT NO.

796


DATE:

796


DRAWING NO.

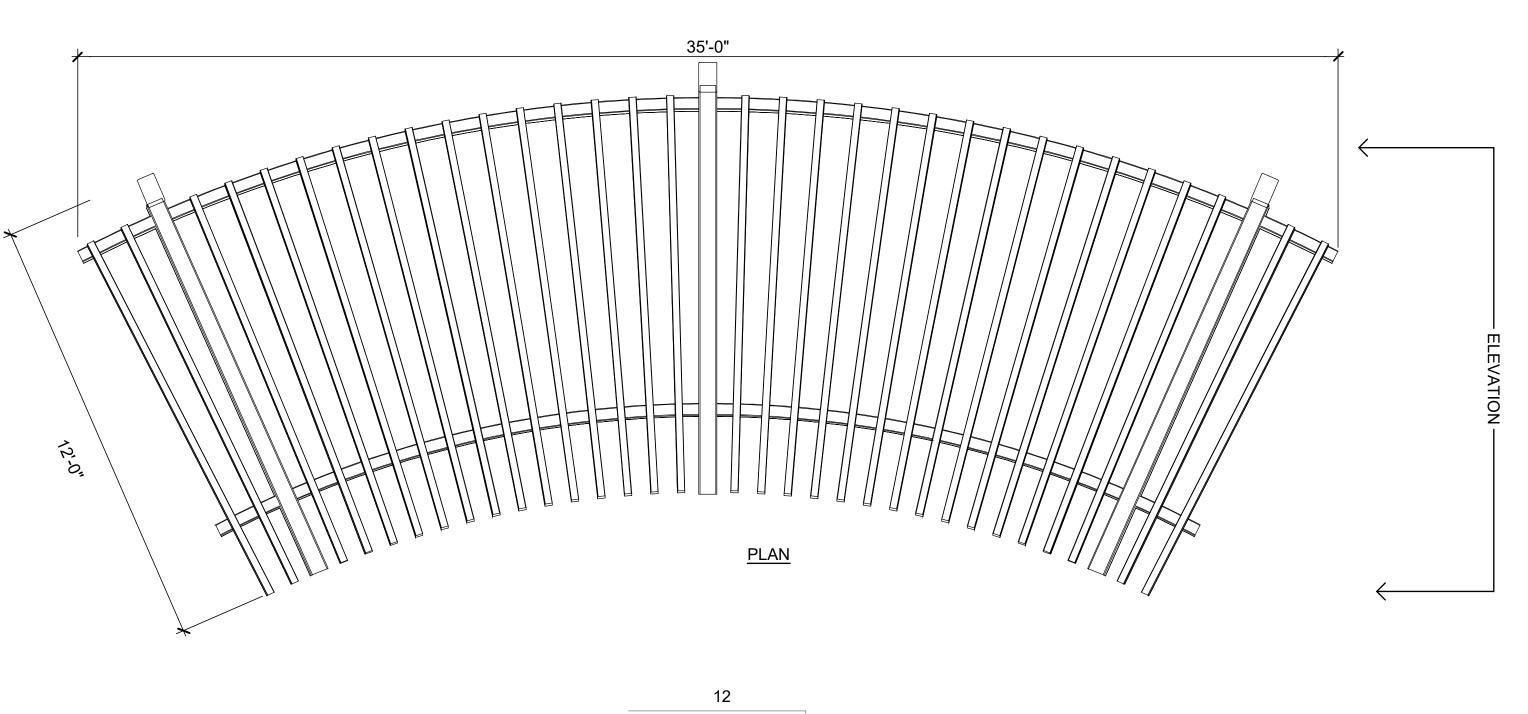


PLOTTED BY: DIVNEY TUNG SCHWALBE, LLP BREANA PARIAN 3/22/2021 4:36:31 PM M:\2015 PROJECTS\PL15006_SUNY PURCHASE 2015\MKW\CURRENT\L503_LANDSCAPE DETAILS.DWG

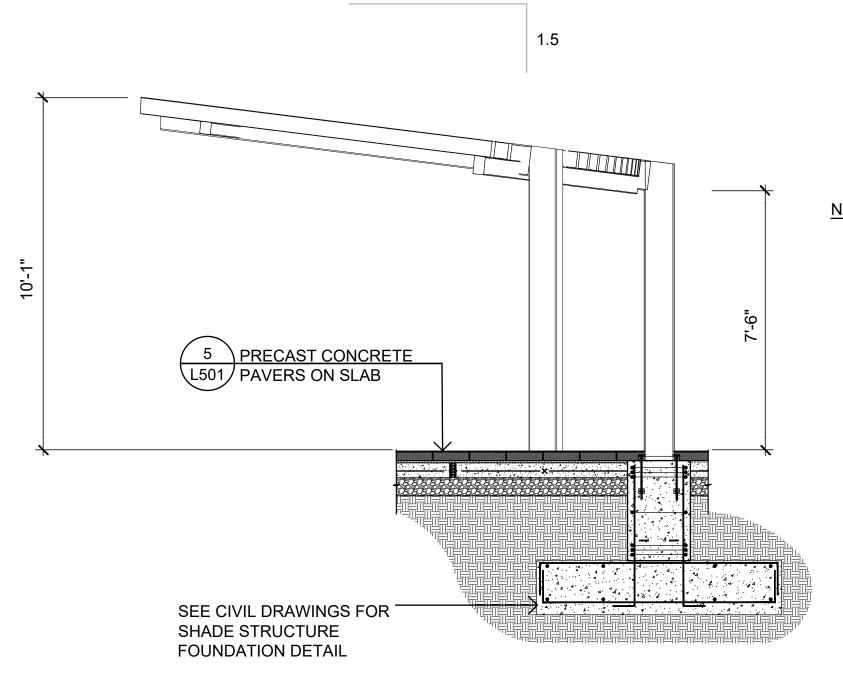

- 1. MILLENNIUM TRELLIS AS MANUFACTURED BY POLIGON PARK ARCHITECTURE OR APPROVED
- 2. BASE PLATE SHALL BE BELOW GRADE AND COLUMN SHALL BE BURIED.
- 3. TRUSS ENDS STYLE SHALL BE MEDITERRANEAN. 4. COLUMNS AND TRUSSES SHALL BE POLI-5000 POWDER POWDER COATED. CONTRACTOR SHALL SUBMIT COLOR SAMPLES PRIOR TO ORDERING. 4.1. COLUMN COLOR SHALL BE FOX HOLLOW GRAY
- 4.2. TRUSS COLOR SHALL BE MEDIUM BRONZE

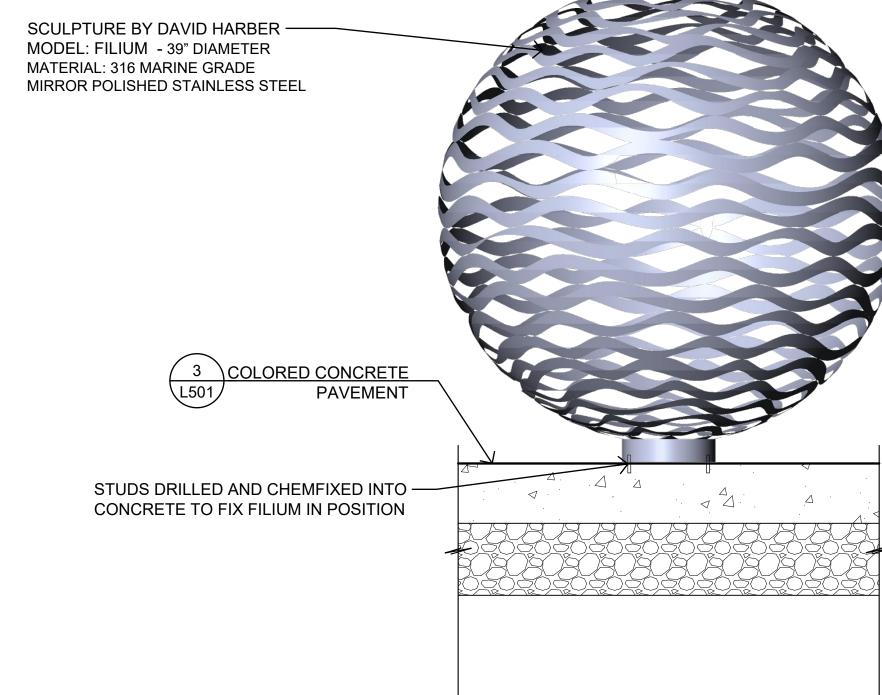

SUN COURTYARD SCULPTURE

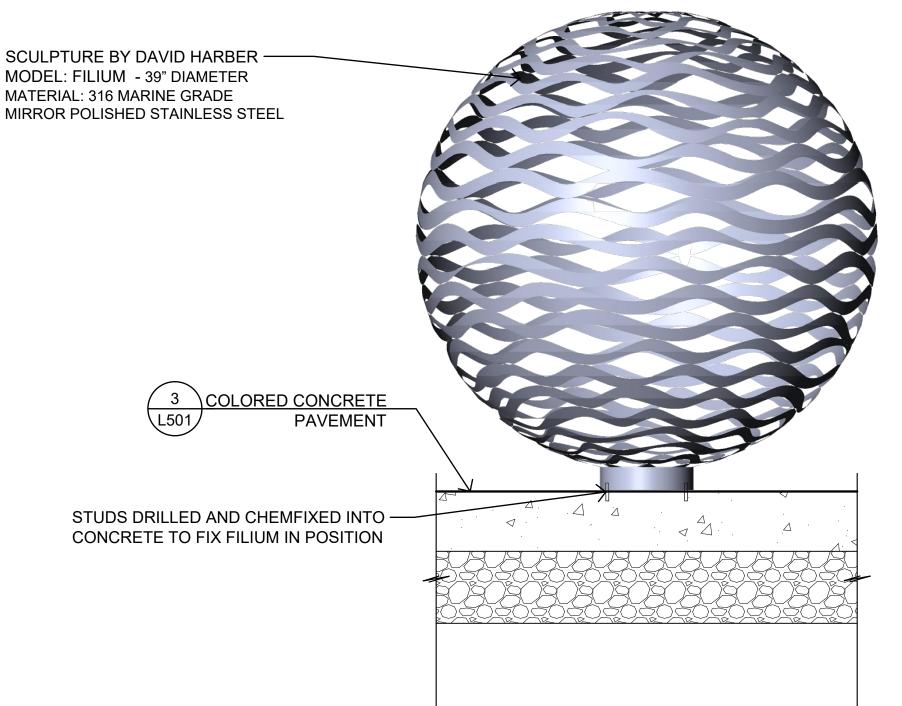



AT PURCHASE COLLEGE Westchester County, New York

SPONSOR

Purchase College Learning Corporation 735 Anderson Hill Road Purchase, NY 10577-1402

PLANNER, CIVIL ENGINEER

DIVNEY • TUNG • SCHWALBE

Divney Tung Schwalbe, LLP One North Broadway White Plains, NY 10601

P: 914.428.0010 F: 914.428.0017

DEVELOPER

LCS DEVELOPMENT

400 Locust Street, Suite 820 Des Moine, IA 50309

<u>ARCHITECT</u> HCM Design, Inc.

750 East Pratt Street Baltimore, MD 21202

LANDSCAPE ARCHITECT

MKW and Associates, LLC 39 Park Avenue

SURVEYOR

Rutherford, NJ 07070

THE CHAZEN COMPANIES

21 Fox Street Poughkeepsie, NY 12601

WETLAND CONSULTANT

WILLIAM KENNY ASSOCIATES LLC 195 Tunxis Hill Cutoff South Fairfield, CT 06825



NOTE: ALL SITE DESIGN CONCEPTS AND INFORMATION INDICATED OR REPRESENTED BY THIS DRAWING ARE OWNED BY AND ARE THE PROPERTY OF DIVNEY TUNG SCHWALBE, LLP. THIS DRAWING WAS CREATED AND DEVELOPED FOR USE ON, AND IN CONNECTION WITH, THE SPECIFIED PROJECT INDICATED HEREON AND SHALL NOT BE USED BY OR DISCLOSED TO ANY PERSON OR ENTITY WHATSOEVER WITHOUT THE WRITTEN PERMISSION OF DIVNEY TUNG SCHWALBE, LLP.

WRITTEN DIMENSIONS ON THIS DRAWING SHALL HAVE PRECEDENCE OVER SCALED MEASUREMENTS. CONTRACTOR SHALL VERIFY AND BE RESPONSIBLE FOR ALL DIMENSIONS AND CONDITIONS ON THE JOB AND THIS OFFICE MUST BE NOTIFIED OF ANY VARIATIONS FROM DIMENSIONS AND CONDITIONS SHOWN BY


LEGAL NOTICE: IT IS A VIOLATION OF ARTICLE 145 OF THE NEW YORK STATE EDUCATION LAW FOR ANY PERSON TO ALTER THIS DOCUMENT IN ANY WAY EXCEPT AS PROVIDED IN SECTION 7209 (2), ARTICLE 145, NEW YORK STATE EDUCATION LAW.


© Copyright Divney Tung Schwalbe, LLP 2019 All rights reserved.


REVISIONS			
	NO.	DATE	ISSUE


LANDSCAPE DETAILS 3 OF 6



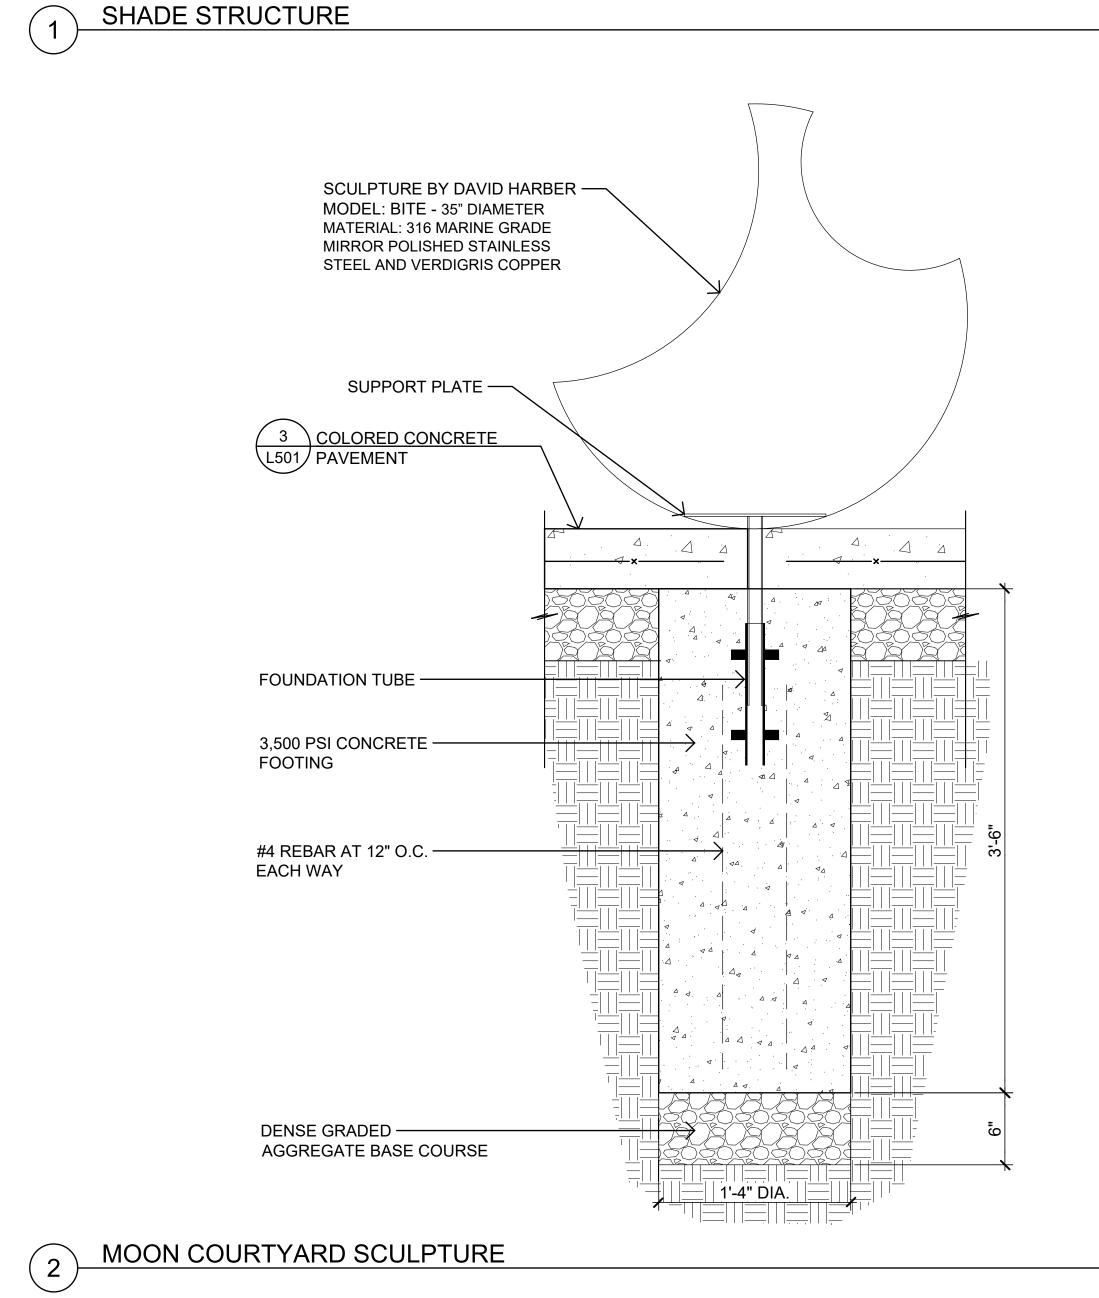

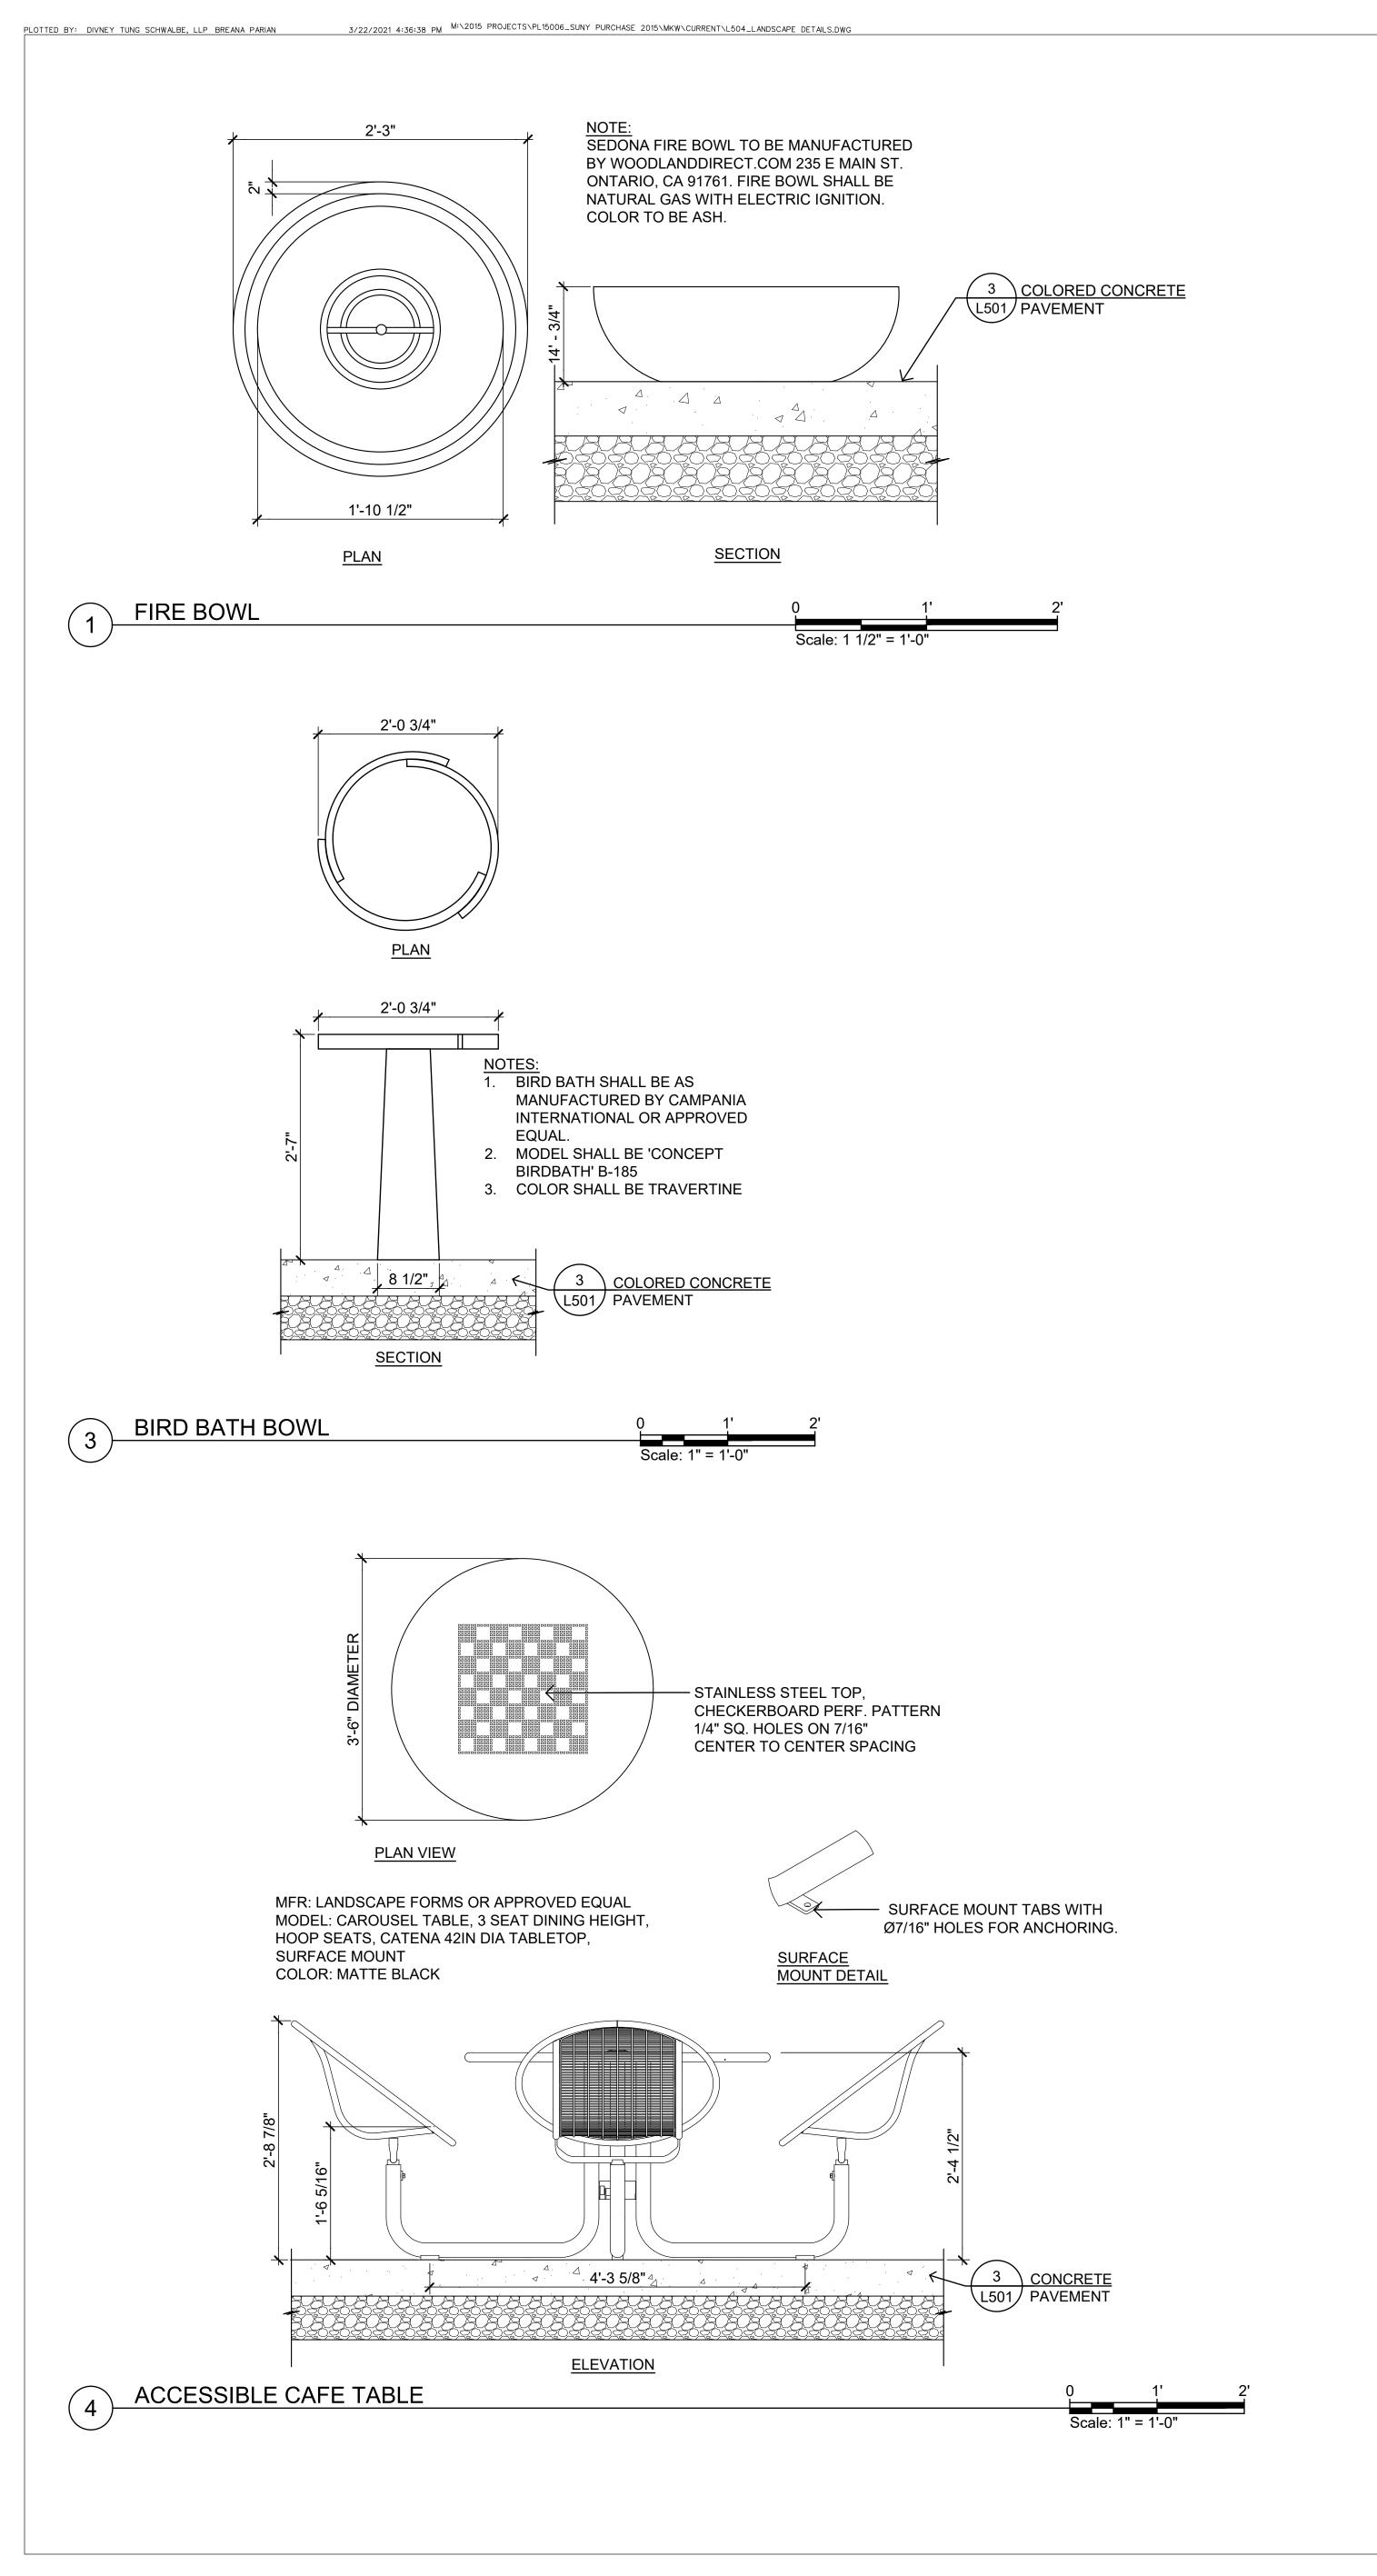

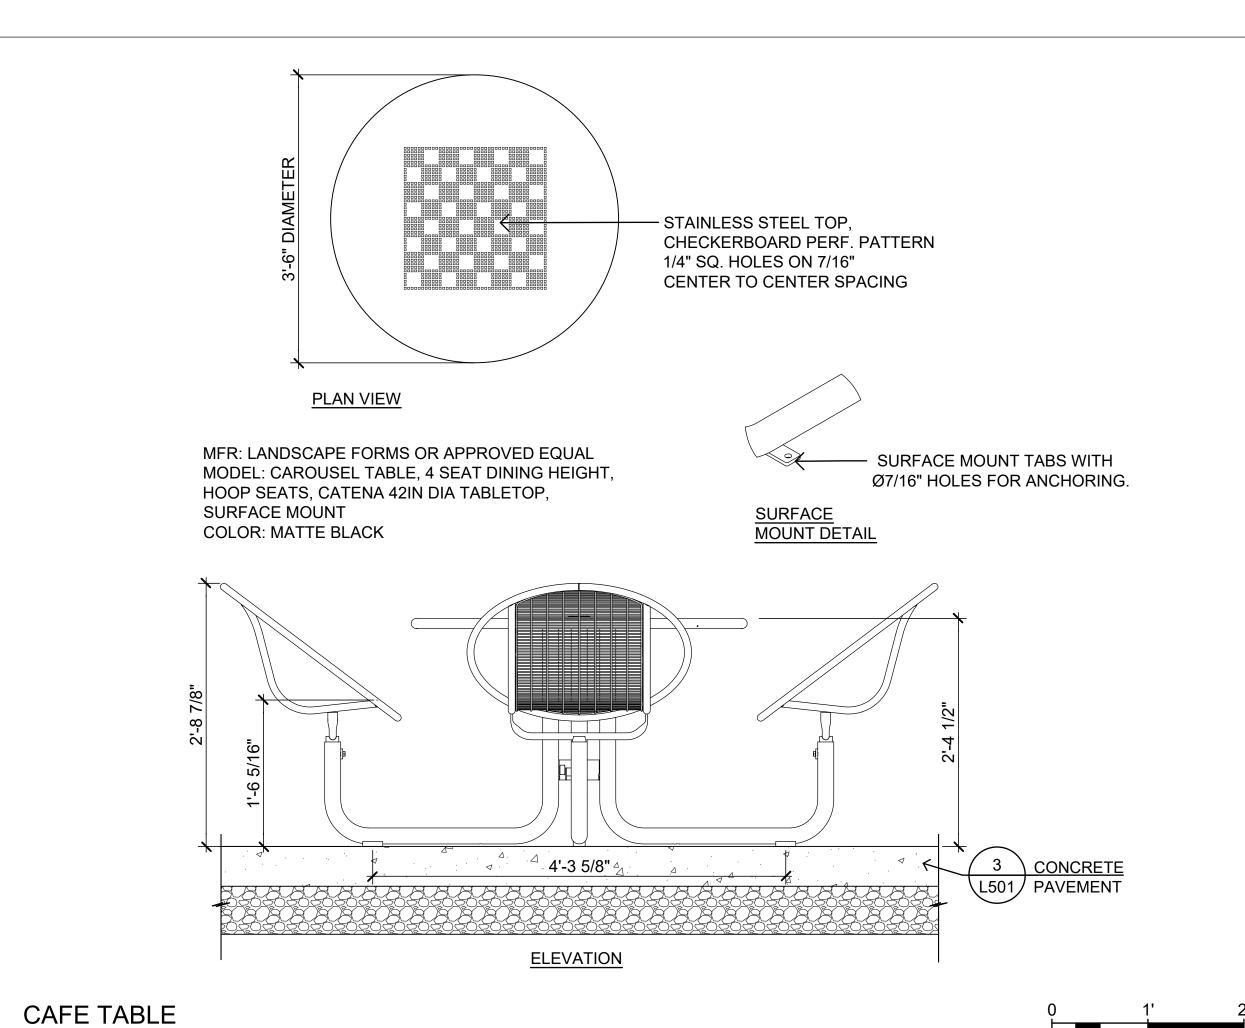


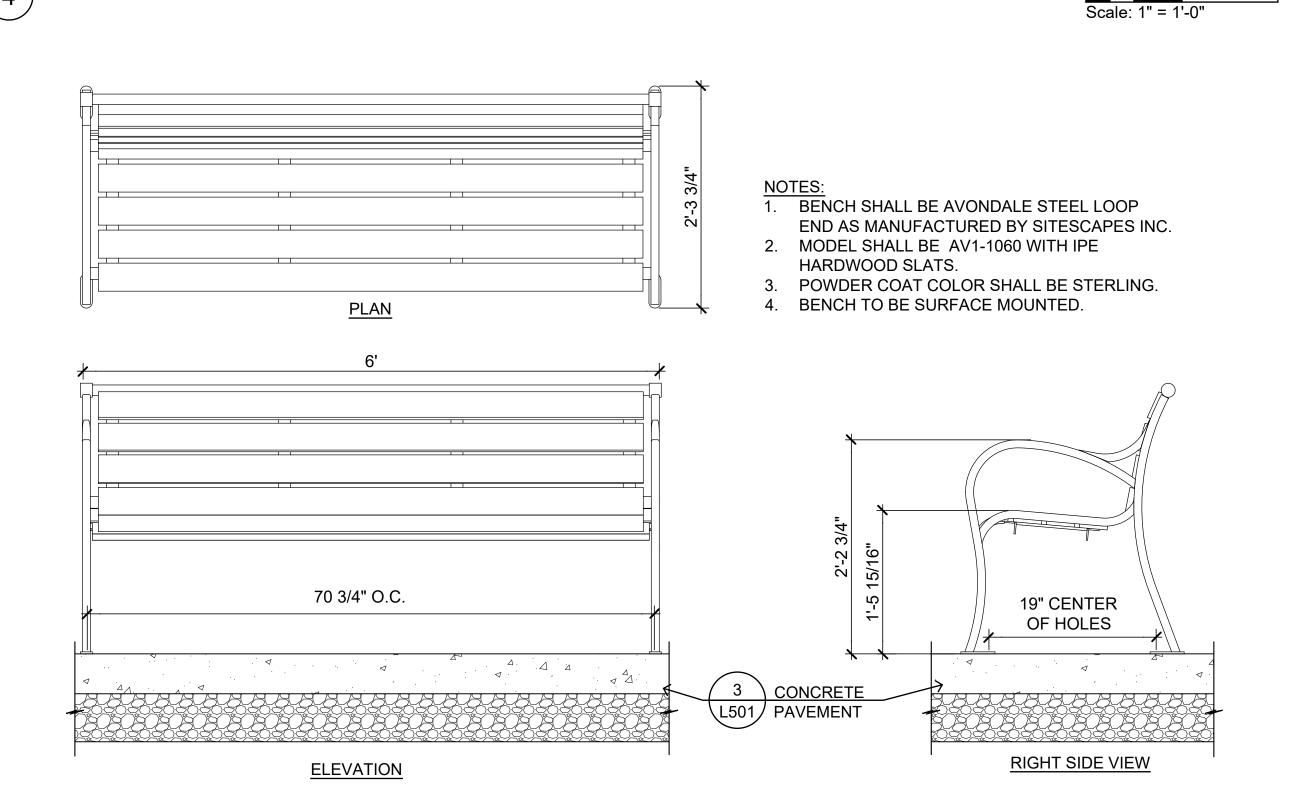



NOTES:
1. CHAIR SHALL BE AVONDALE AS

MANUFACTURED BY SITESCAPES INC.

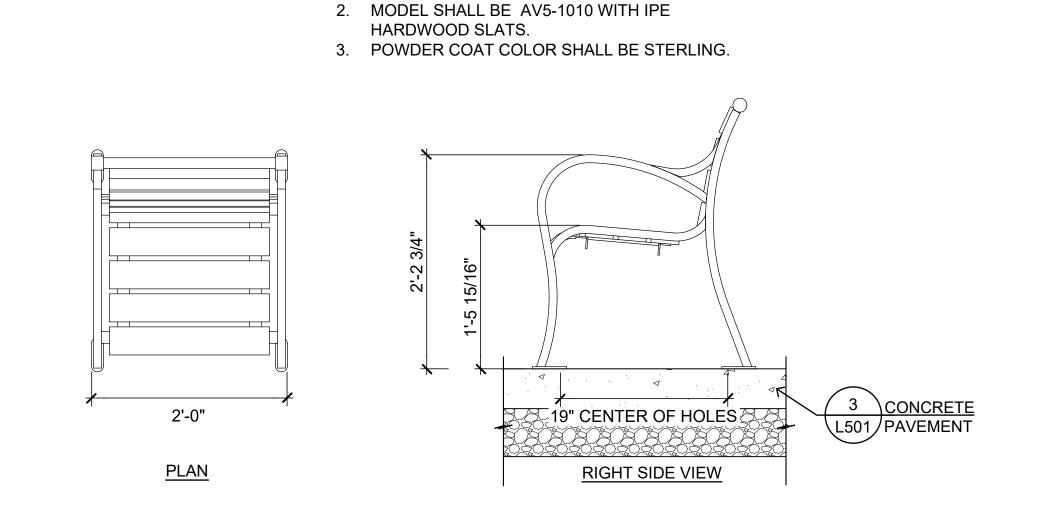







AT PURCHASE COLLEGE
Westchester County, New York

<u>SPONSOR</u>

Purchase College Learning Corporation 735 Anderson Hill Road Purchase, NY 10577-1402

PLANNER, CIVIL ENGINEER

DIVNEY • TUNG • SCHWALBE

Divney Tung Schwalbe, LLP One North Broadway White Plains, NY 10601

White Plains, NY 1060² P: 914.428.0010

F: 914.428.0017

DEVELOPER LCS DEVELOPMENT

400 Locust Street, Suite 820 Des Moine, IA 50309

ARCHITECT

HCM Design, Inc. 750 East Pratt Street Baltimore, MD 21202

39 Park Avenue Rutherford, NJ 07070

LANDSCAPE ARCHITECT
MKW and Associates, LLC

SURVEYOR

THE CHAZEN COMPANIES 21 Fox Street

Poughkeepsie, NY 12601

WETLAND CONSULTANT
WILLIAM KENNY ASSOCIATES LLC
195 Tunxis Hill Cutoff South
Fairfield, CT 06825



NOTE: ALL SITE DESIGN CONCEPTS AND INFORMATION INDICATED OR REPRESENTED BY THIS DRAWING ARE OWNED BY AND ARE THE PROPERTY OF DIVNEY TUNG SCHWALBE, LLP. THIS DRAWING WAS CREATED AND DEVELOPED FOR USE ON, AND IN CONNECTION WITH, THE SPECIFIED PROJECT INDICATED HEREON AND SHALL NOT BE USED BY OR DISCLOSED TO ANY PERSON OR ENTITY WHATSOEVER WITHOUT THE WRITTEN PERMISSION OF DIVNEY TUNG SCHWALBE, LLP.

WRITTEN DIMENSIONS ON THIS DRAWING SHALL HAVE PRECEDENCE OVER SCALED MEASUREMENTS. CONTRACTOR SHALL VERIFY AND BE RESPONSIBLE FOR ALL DIMENSIONS AND CONDITIONS ON THE JOB AND THIS OFFICE MUST BE NOTIFIED OF ANY VARIATIONS FROM DIMENSIONS AND CONDITIONS SHOWN BY THESE DRAWINGS.

LEGAL NOTICE: IT IS A VIOLATION OF ARTICLE 145 OF THE NEW YORK STATE EDUCATION LAW FOR ANY PERSON TO ALTER THIS


DOCUMENT IN ANY WAY EXCEPT AS PROVIDED IN SECTION 7209 (2), ARTICLE 145, NEW YORK STATE EDUCATION LAW.


© Copyright Divney Tung Schwalbe, LLP 2019 All rights reserved.

NO.	DATE	ISSUE
		-
		-

DRAWING TITI


LANDSCAPE DETAILS 4 OF 6

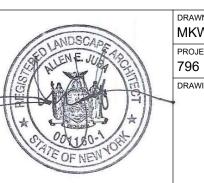


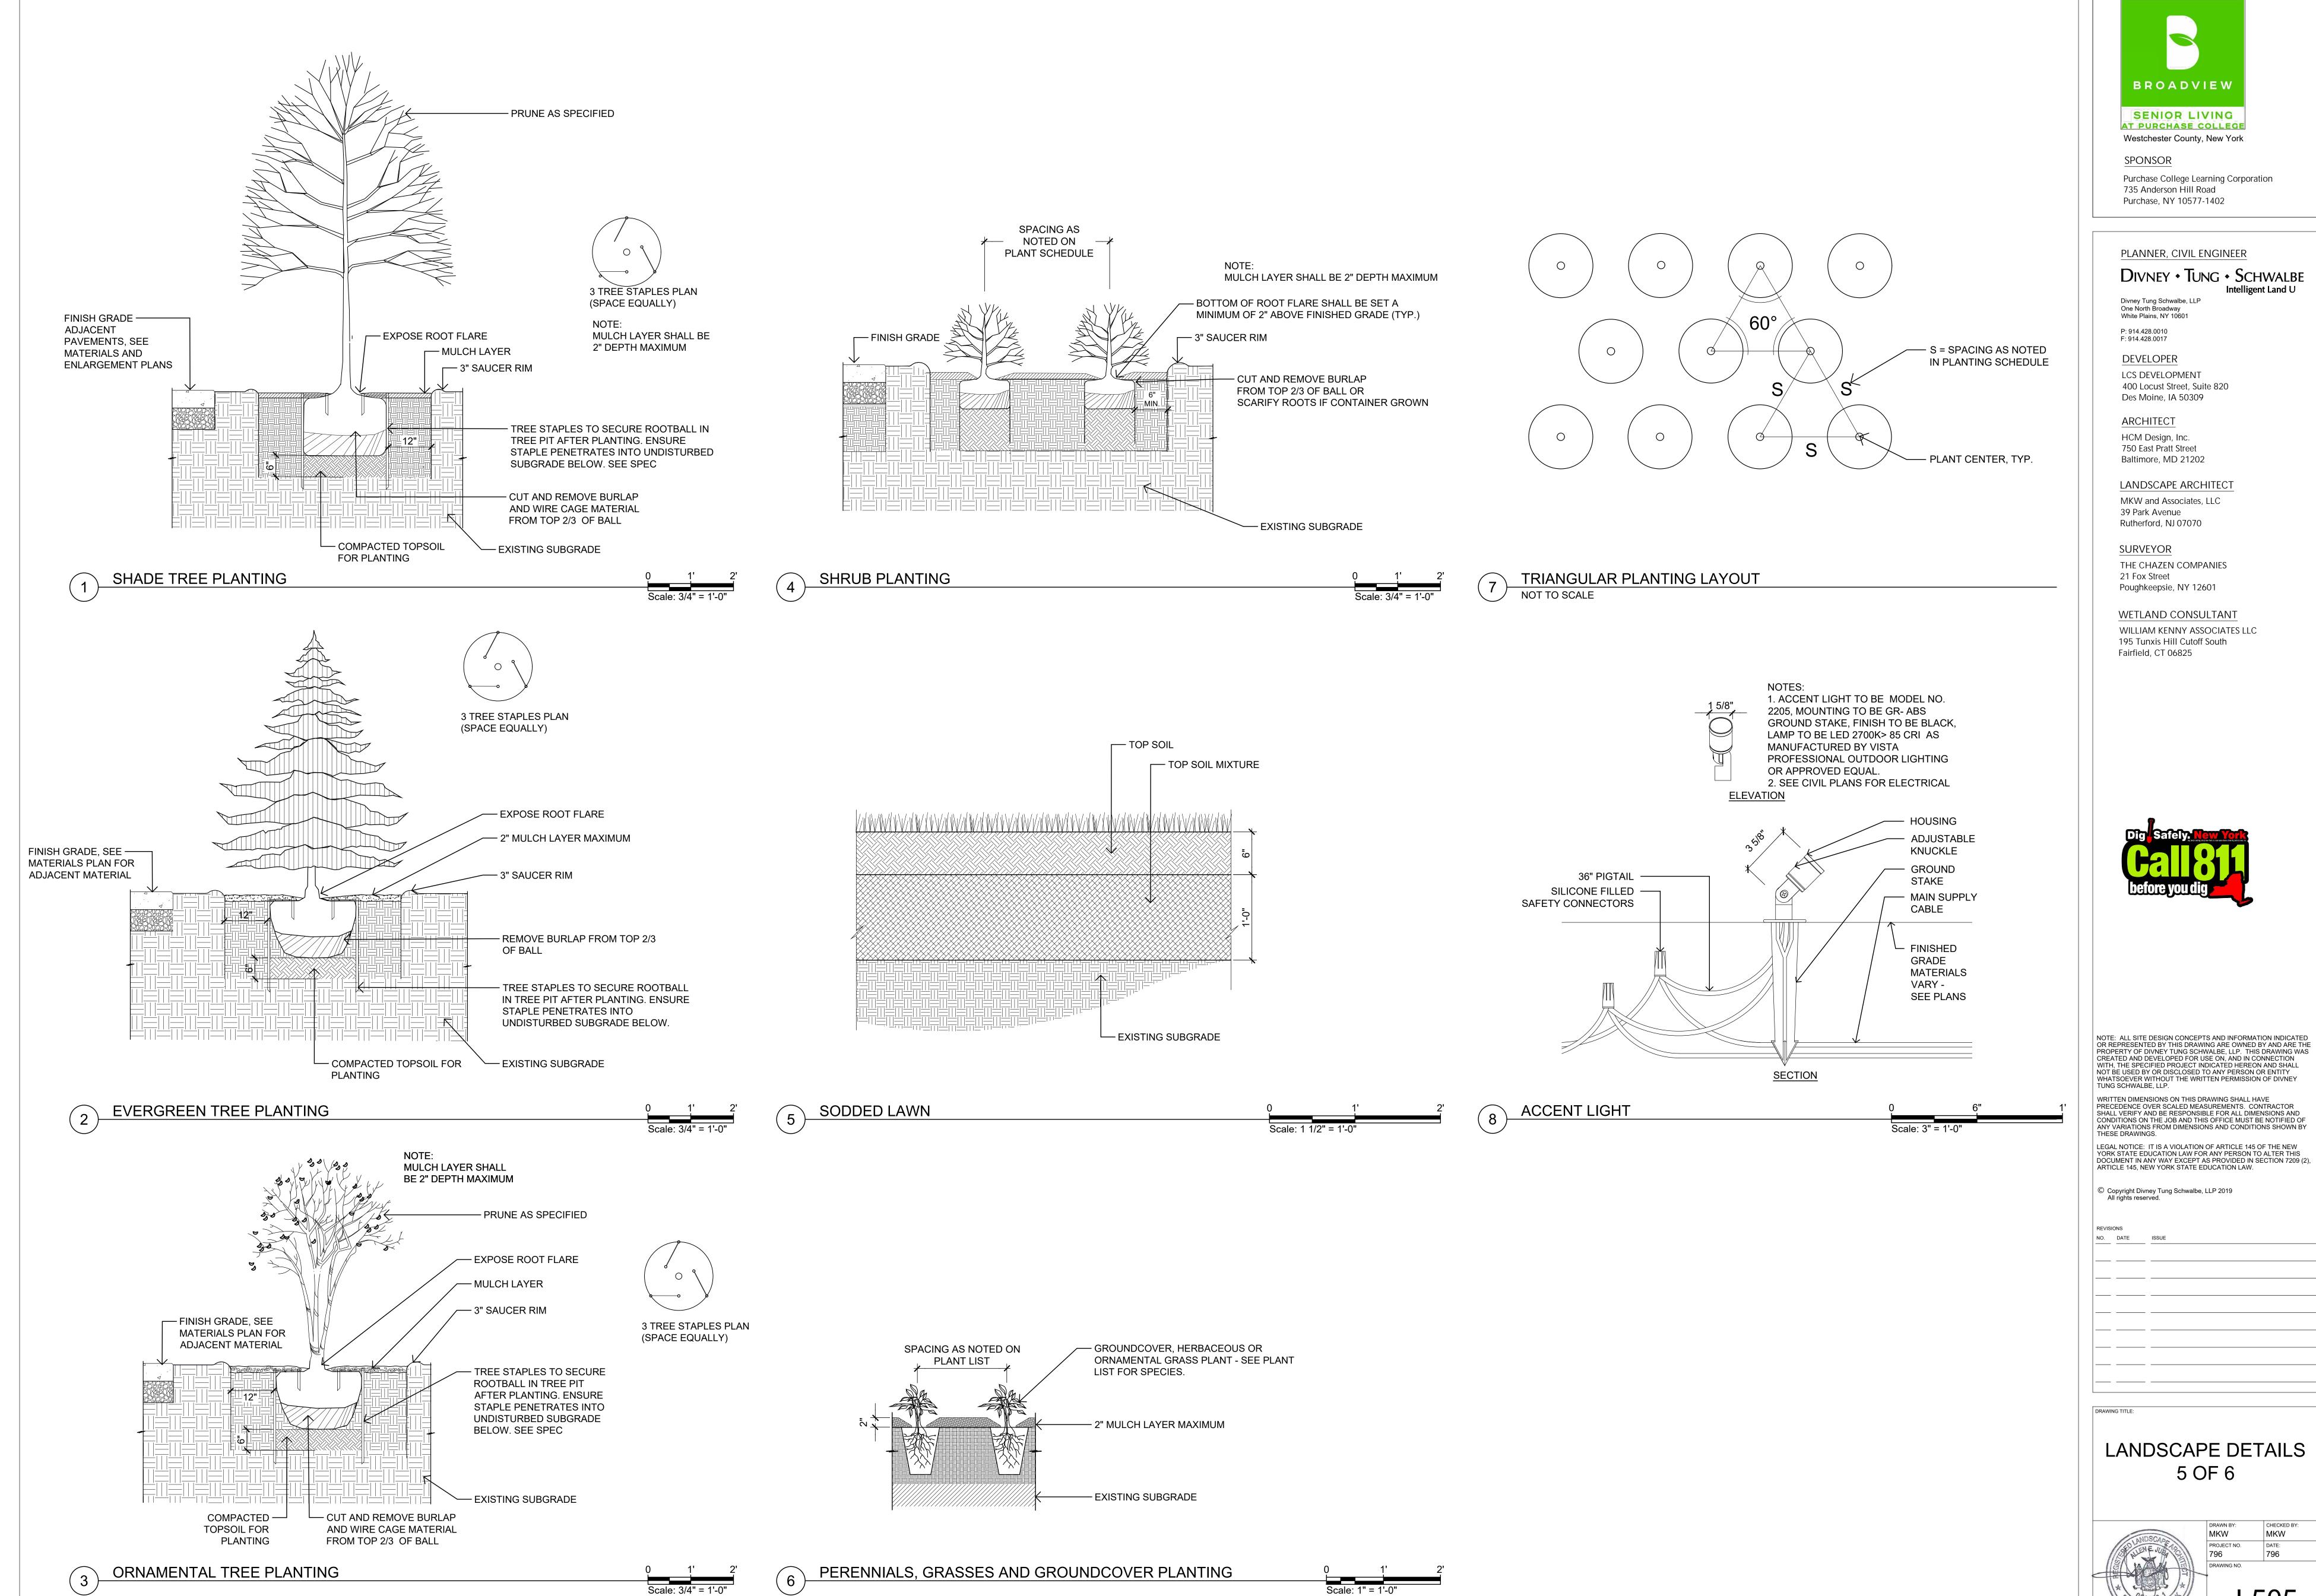


PLOTTED BY: DIVNEY TUNG SCHWALBE, LLP BREANA PARIAN 3/22/2021 4:36:48 PM M:\2015 PROJECTS\PL15006_SUNY PURCHASE 2015\MKW\CURRENT\L505_LANDSCAPE DETAILS.DWG



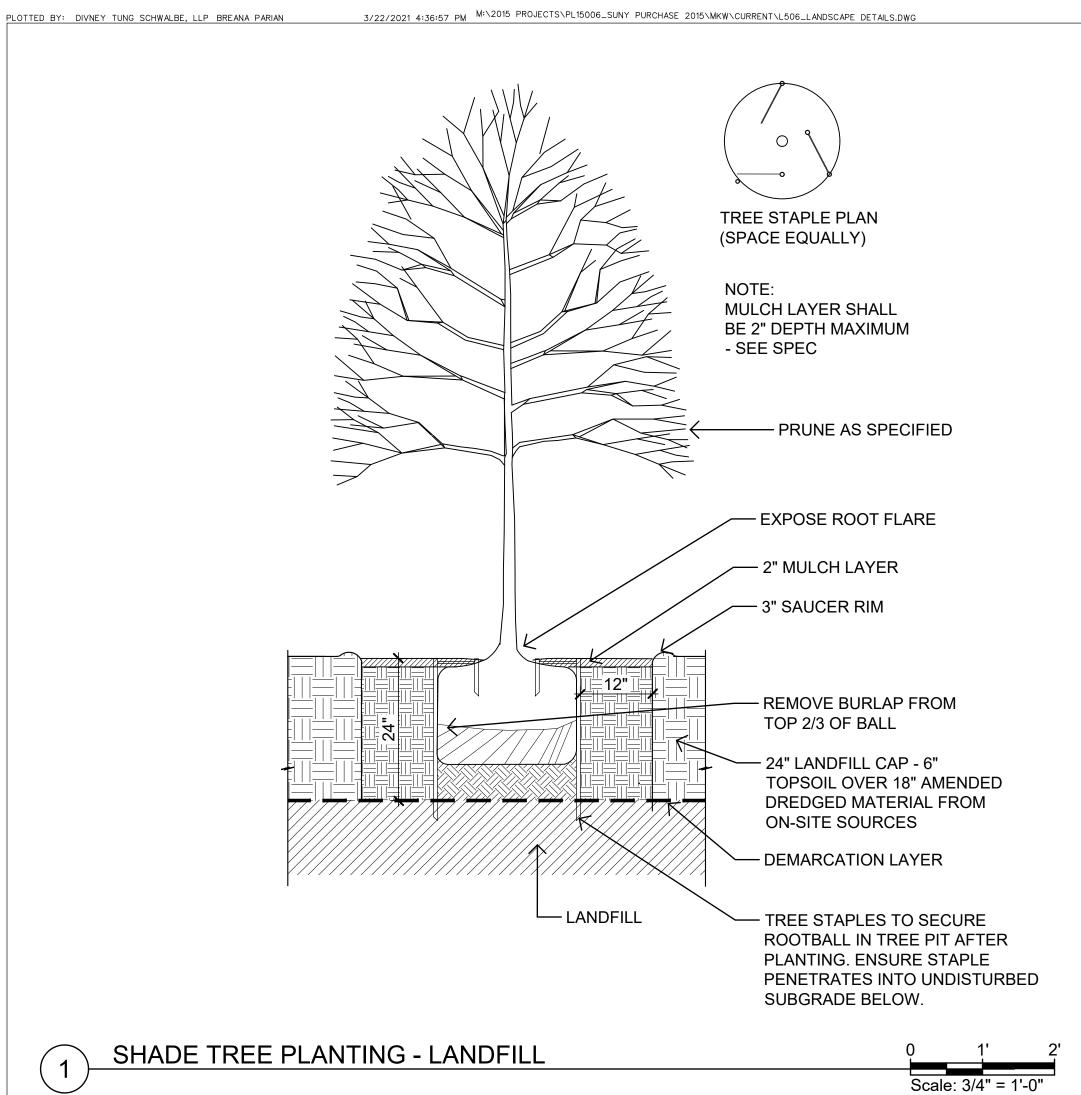

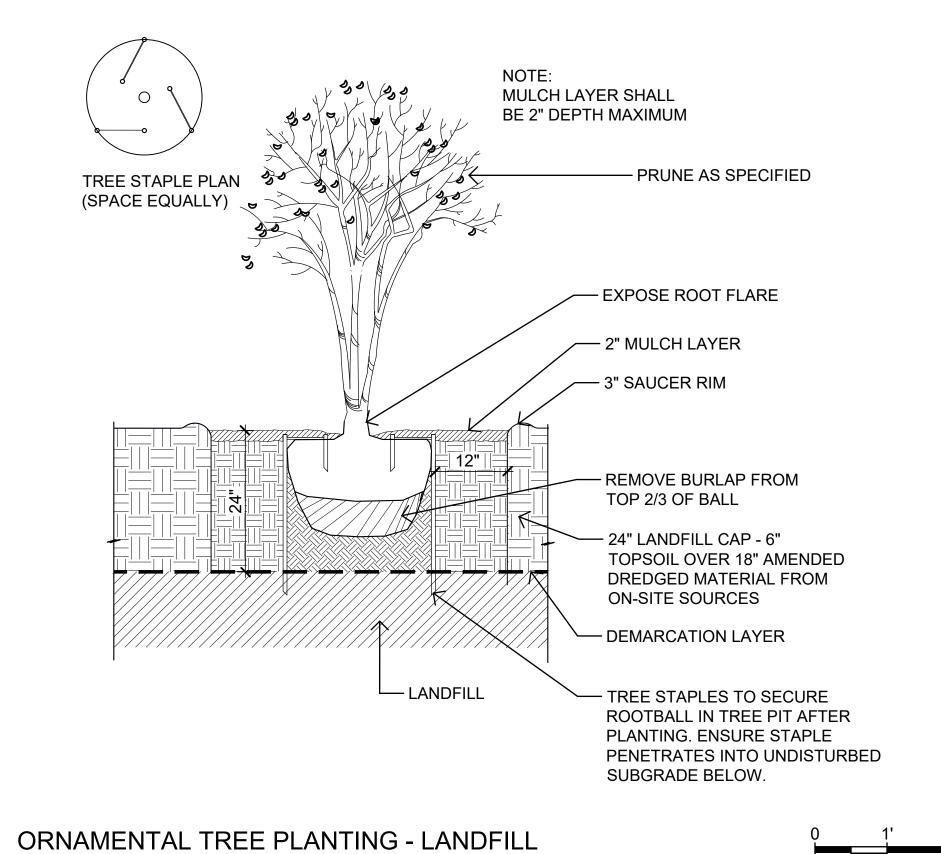

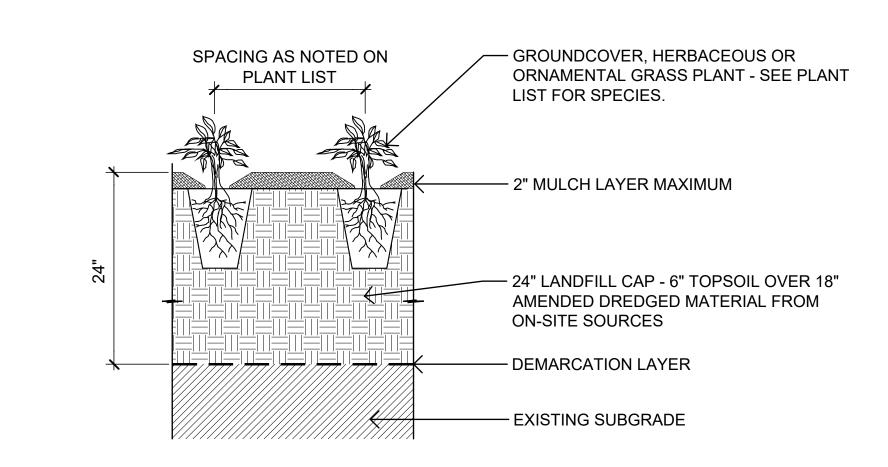

PERENNIALS, GRASSES AND GROUNDCOVER-LANDFILL


TREE STAPLE PLAN (SPACE EQUALLY) - EXPOSE ROOT FLARE — 2" MULCH LAYER → 3" SAUCER RIM REMOVE BURLAP FROM TOP 2/3 OF BALL 24" LANDFILL CAP - 6" TOPSOIL OVER 18" AMENDED DREDGED MATERIAL FROM ON-SITE SOURCES DEMARCATION LAYER - TREE STAPLES TO SECURE LANDFILL ROOTBALL IN TREE PIT AFTER

EVERGREEN TREE PLANTING - LANDFILL


PLANTING. ENSURE STAPLE

SUBGRADE BELOW.

PENETRATES INTO UNDISTURBED

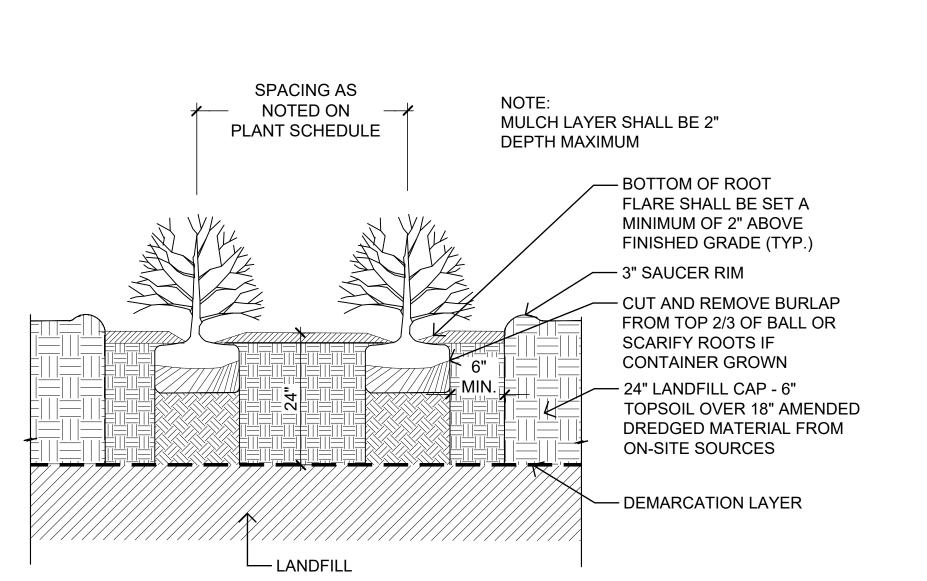

SHRUB PLANTING - LANDFILL

 

BROADVIEW SENIOR LIVING AT PURCHASE COLLEGE

Westchester County, New York

SPONSOR Purchase College Learning Corporation

735 Anderson Hill Road Purchase, NY 10577-1402

PLANNER, CIVIL ENGINEER

DIVNEY • TUNG • SCHWALBE

Divney Tung Schwalbe, LLP One North Broadway White Plains, NY 10601

P: 914.428.0010 F: 914.428.0017

DEVELOPER LCS DEVELOPMENT 400 Locust Street, Suite 820

Des Moine, IA 50309

ARCHITECT

HCM Design, Inc. 750 East Pratt Street

Baltimore, MD 21202

LANDSCAPE ARCHITECT MKW and Associates, LLC 39 Park Avenue

SURVEYOR

Scale: 1" = 1'-0"

Rutherford, NJ 07070

THE CHAZEN COMPANIES 21 Fox Street

Poughkeepsie, NY 12601

WETLAND CONSULTANT WILLIAM KENNY ASSOCIATES LLC 195 Tunxis Hill Cutoff South Fairfield, CT 06825



NOTE: ALL SITE DESIGN CONCEPTS AND INFORMATION INDICATED OR REPRESENTED BY THIS DRAWING ARE OWNED BY AND ARE THE PROPERTY OF DIVNEY TUNG SCHWALBE, LLP. THIS DRAWING WAS CREATED AND DEVELOPED FOR USE ON, AND IN CONNECTION WITH, THE SPECIFIED PROJECT INDICATED HEREON AND SHALL NOT BE USED BY OR DISCLOSED TO ANY PERSON OR ENTITY WHATSOEVER WITHOUT THE WRITTEN PERMISSION OF DIVNEY TUNG SCHWALBE, LLP.

WRITTEN DIMENSIONS ON THIS DRAWING SHALL HAVE PRECEDENCE OVER SCALED MEASUREMENTS. CONTRACTOR SHALL VERIFY AND BE RESPONSIBLE FOR ALL DIMENSIONS AND CONDITIONS ON THE JOB AND THIS OFFICE MUST BE NOTIFIED OF ANY VARIATIONS FROM DIMENSIONS AND CONDITIONS SHOWN BY THESE DRAWINGS.

LEGAL NOTICE: IT IS A VIOLATION OF ARTICLE 145 OF THE NEW YORK STATE EDUCATION LAW FOR ANY PERSON TO ALTER THIS DOCUMENT IN ANY WAY EXCEPT AS PROVIDED IN SECTION 7209 (2), ARTICLE 145, NEW YORK STATE EDUCATION LAW.

© Copyright Divney Tung Schwalbe, LLP 2019 All rights reserved.

NO.	DATE	ISSUE

LANDSCAPE DETAILS 6 OF 6



