

(BURGERS and FRIES) 10718 RICHMOND HIGHWAY

LORTON, VA 22079 THESE DRAWINGS AND SPECIFICATIONS ARE THE CONFIDENTIAL AND PROPRIETARY PROPERTY OF FIVE GUYS ENTERPRISES, LLC. AND SHALL NOT BE COPIED OR REPRODUCED WITHOUT WRITTEN AUTHORIZATION.

PJH Design Group Inc.

RETAIL DESIGN CONSULTANTS



Thomas J. Mesuk ARCHITECT, L.L.C.

197 Valley Boulevard Wood-Ridge, New Jersey 07075 Facsimile (201) 438-1560

NEW JERSEY

NORTH CAROLINA NEW HAMPSHIRE Lic. No. 9536 Lic. No. 4390 REV. DATE DESCRIPTION

| IXL V. | D/IIL | DESCRIPTION |
|--------|--------------|---|
| | | |
| | | |
| | 23 Aug 2021 | Final Owner, Landlord Review & G.C. Bid |
| | 30 June 2021 | 5 Guys Design Ticket Review - Revised 2 |
| | 24 June 2021 | 5 Guys Design Ticket Review |
| - | 12 June 2021 | Existing Plan / Proposed New Layout |

FIVE GUYS BURGERS & FRIES PALMERONE PLAZA TENANT SPACE C UNION AVENUE (ROUTE 300) NEWBURGH, NEW YORK 12550 FIVE GUYS STORE #1090

DRAWING TITLE:


PLUMBING ROUGH IN FLOOR PLAN DETAILS

PROJECT No: -DRAWN BY: -CHECKED BY: -

RA / PE SEAL:

P-101.00

OF SHEETS

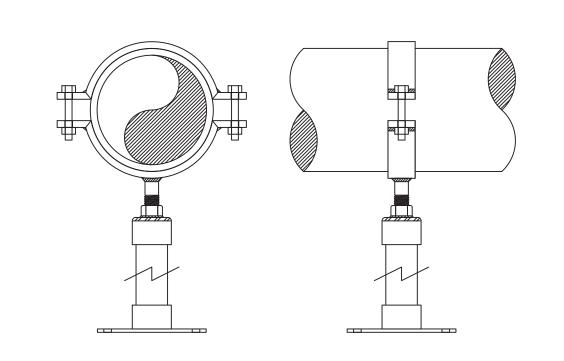



9 PIPE SUPPORT (3 & 4 COMPARTMENT SINKS

LINES TO BIB RACK, TEA & FREESTYLE

BY COKE

3/4" BALL VALVE SHUTOFF


3/4" BALL VALVE SHUTOFF W/ 1/2"

3/4" IMPT, ICE MACH

SCALE REDUCER -

WATER BOOSTER

PROVIDE 120V

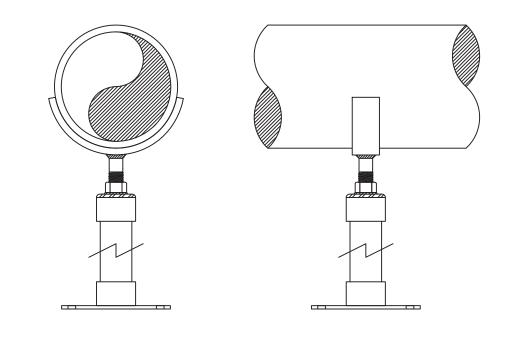

LINES BY COKE TO BIB RACK, TEA & SODA FREESTYLE

ICE 1

LEGEND

BY COKE

BY PLUMBER

DCK = DUAL CHECK VALVE, WATTS 9D OR EQUAL (TYP.)

ICE 2



1/2" SHUTOFF,

BEV SYSTEM PIPING DIAG-3M

- 4. STANDON MODEL SUPPORTS AS MANUFACTURED BY MATERIAL RESOURCES INC., FOREST GROVE, OR.503-533-5256P, 503-533-5501F

1. PROVIDE EITHER FULL CIRCLE SUPPORT OR SADDLE SUPPORTS FOR INDIVIDUAL SINK DRAIN

PIPING FOR 3 & 4 COMPARTMENT SINK PIPING THAT RUNS HORIZONTAL TO FLOOR SINKS.

FABRICATED SUPPORTS ARE ALLOWED. MATERIAL TO BE A36 STEEL WITH A GALVANIZED FINISH UNLESS INDICATED OTHERWISE IN SPECIFICATIONS. UPPER AND LOWER MATCHING

SADDLES ARE EACH TO ENCOMPASS 170° OF PIPE, AND ARE TO BE FORMED TO ACTUAL PIPE DIAMETER. BASE IS TO BE ANCHORED TO FLOOR, AND INSTALLER IS TO WELD EXTENSION

PIPE TO BASE AND COLLAR AFTER INSTALLATION. A NEOPRENE LINER IS REQUIRED WHEN

3. SADDLE SUPPORTS ARE TO BE FACTORY FABRICATED UNITS. NO CONTRACTOR FABRICATED SUPPORTS ARE ALLOWED. MATERIAI TO BE A36 STEEL WITH A GALVANIZED FINISH UNLESS

TO BE FORMED TO ACTUAL PIPE DIAMETER. A NEOPRENE LINER IS REQUIRED WHEN SUPPORTING STEEL OR PVC PIPE. SUPPORTS SHALL BE STANDON MODEL S92 OR

CIRCUMFERENCE FOR PIPE SIZES UP TO 24", AND 120° FOR LARGER DIAMETER'S. SADDLE IS


SUPPORTING STEEL OR PVC PIPE. SUPPORTS SHALL BE STANDON MODEL C92 OR

INDICATED OTHERWISE IN SPECIFICATIONS. SADDLE TO ENCOMPASS 170° OF

APPROVED EQUALS.

APPROVED EQUALS.

2. FULL CIRCLE CLAMP SUPPORTS ARE TO BE FACTORY FABRICATED UNITS. NO CONTRACTOR

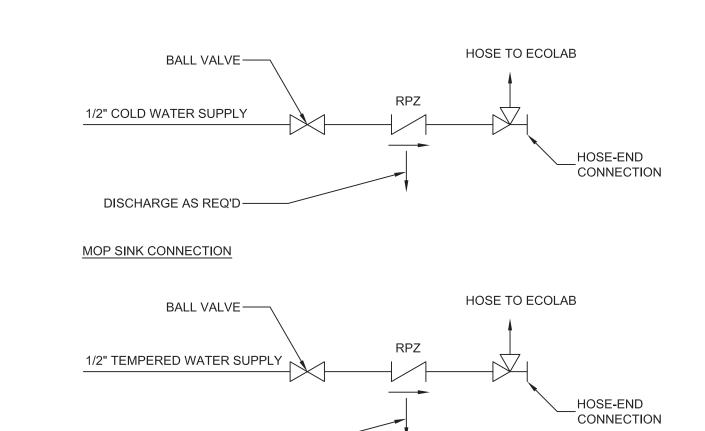

10718 RICHMOND HIGHWAY LORTON, VA 22079

THESE DRAWINGS AND SPECIFICATIONS ARE THE CONFIDENTIAL AND PROPRIETARY PROPERTY OF FIVE GUYS ENTERPRISES, LLC. AND SHALL NOT BE COPIED OR REPRODUCED WITHOUT WRITTEN AUTHORIZATION.

PJH Design Group Inc.
925 Woodview Road, Brielle, New Jersey 08730

Thomas J. Mesuk ARCHITECT, L.L.C.

NORTH CAROLINA

Lic. No. 9536

23 Aug 2021 Final Owner, Landlord Review & G.C. Bid

24 June 2021 5 Guys Design Ticket Review

FIVE GUYS BURGERS & FRIES

UNION AVENUE (ROUTE 300) NEWBURGH, NEW YORK 12550

FIVE GUYS STORE #1090

PALMERONE PLAZA

TENANT SPACE C

12 June 2021 | Existing Plan / Proposed New Layout

5 Guys Design Ticket Review - Revised 2

P-102.00

OF SHEETS

DESCRIPTION

NEW HAMPSHIRE

Lic. No. 4390

197 Valley Boulevard

Facsimile (201) 438-1560

NEW JERSEY

PROJECT:

DRAWING TITLE

DETAILS

PROJECT No: DRAWN BY:

CHECKED BY:

RA / PE SEAL:

Wood-Ridge, New Jersey 07075


P 908-233-7700, pjhanas136@gmail.com


RETAIL DESIGN CONSULTANTS

3-COMP SINK CONNECTION

DISCHARGE AS REQ'D-

3 CHEMICAL SYSTEM CONNECTION NOT TO SCALE

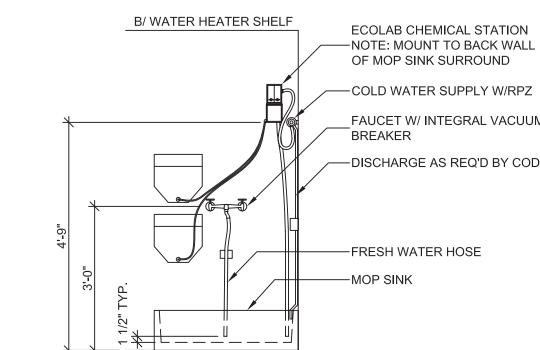

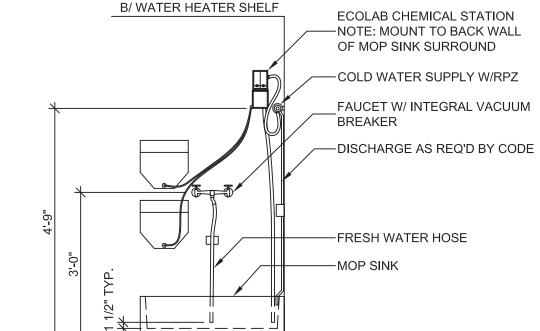

8 WATER FILTER DETAIL 1"=1'-0"

— FILTER W/ SCALE

1/2" WATER LINE FOR SODA MACHINE TO PASS THROUGH THE COOLER

BOX, COIL 50 FEET OF PIPING ON CEILING OF BOX (HANG AND SUPPOR

THROUGH COOLER BOX ALSO WHEN SCOTSMAN MACHINES USED NOT HOSHIZAKI, SEE PREVIOUS NOTES. ALL PIPES PASSING THROUGH

PENETRATIONS THROUGH COOLER BOX, CAULK AS REQUIRED WITH NON-SHRINKABLE CAULK. 1/2" WATER LINE FOR ICE MACHINE TO PASS

AS REQUIRED) END AT BALL VALVE NEAR BIB RACK. SEAL

ADDITIVE

FIVE GUYS JUNE 2016 UPDATE LIGHT SWITCH BANK / MUSIC VOLUME CONTROLS LIGHT SWITCH/MUSIC VOLUME CONTROLS SHALL BE RELOCATED TO THE MANAGERS AREA WHENEVER THE WALL AREA NEXT TO ELIASON DOOR SEPARATING THE KITCHEN AND PREP ROOM IS IN PROXIMITY TO ANY SINK GREASE CUP, OR OTHER WATER RELATED FIXTURE OR DEVICE THAT MAY


OUTLET

3/4" IMPT


MACHINES

NOTE (ONLY IN SOUTHERN CLIMATES):


COOLER BOXES ARE POST WATER FILTER.

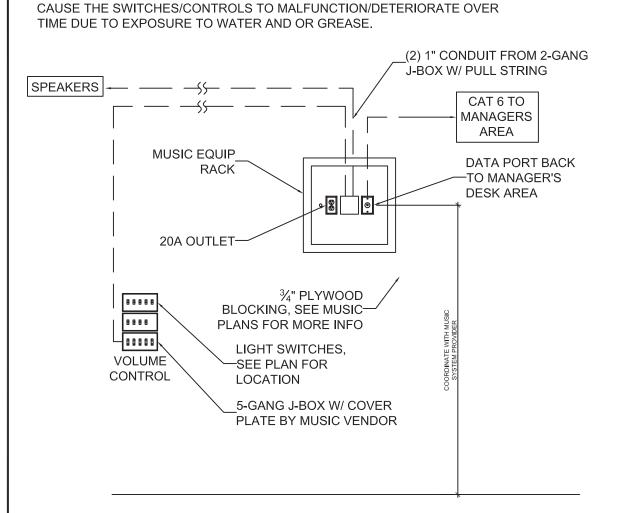


6 MUSIC EQUIP RACK DET

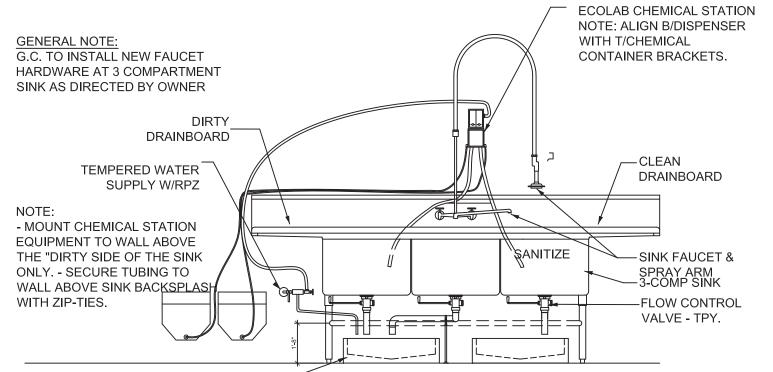

G.C. TO VERIFY CLEARANCE FOR MUSTEE MOPSINK DRAIN AND ADJUST SINK SUPPORTS AS REQUIRED - VERIFY AT SITE

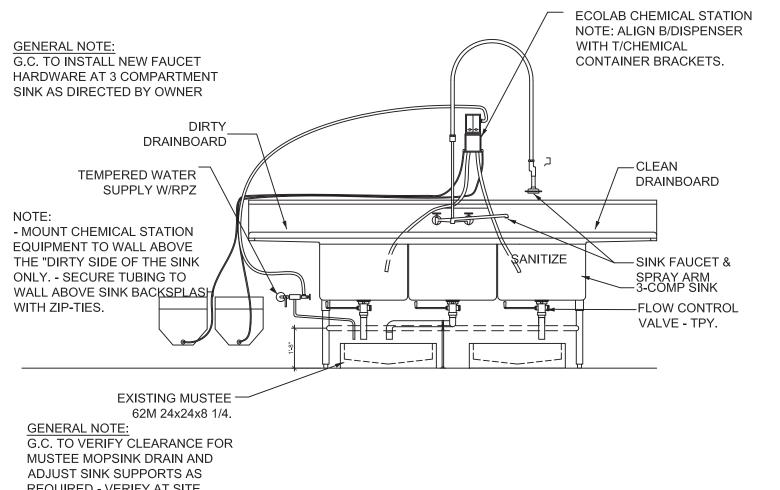

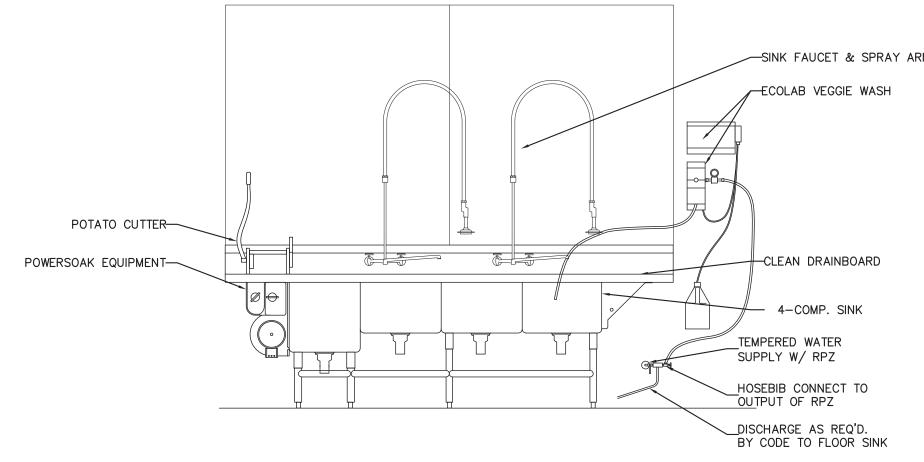

4 3 COMPARTMENT WAREWASH SINK



