




C:\Users\jgblake\OneDrive\Documents\Projects\2018\10\Emergency Housing Shower\Bldg CAD Files\1001 MEP Shower Plans.dwg
 one eighth inch = one foot
 one quarter inch = one foot
 three eighths inch = one foot
 one half inch = one foot
 three quarters inch = one foot
 one inch = one foot

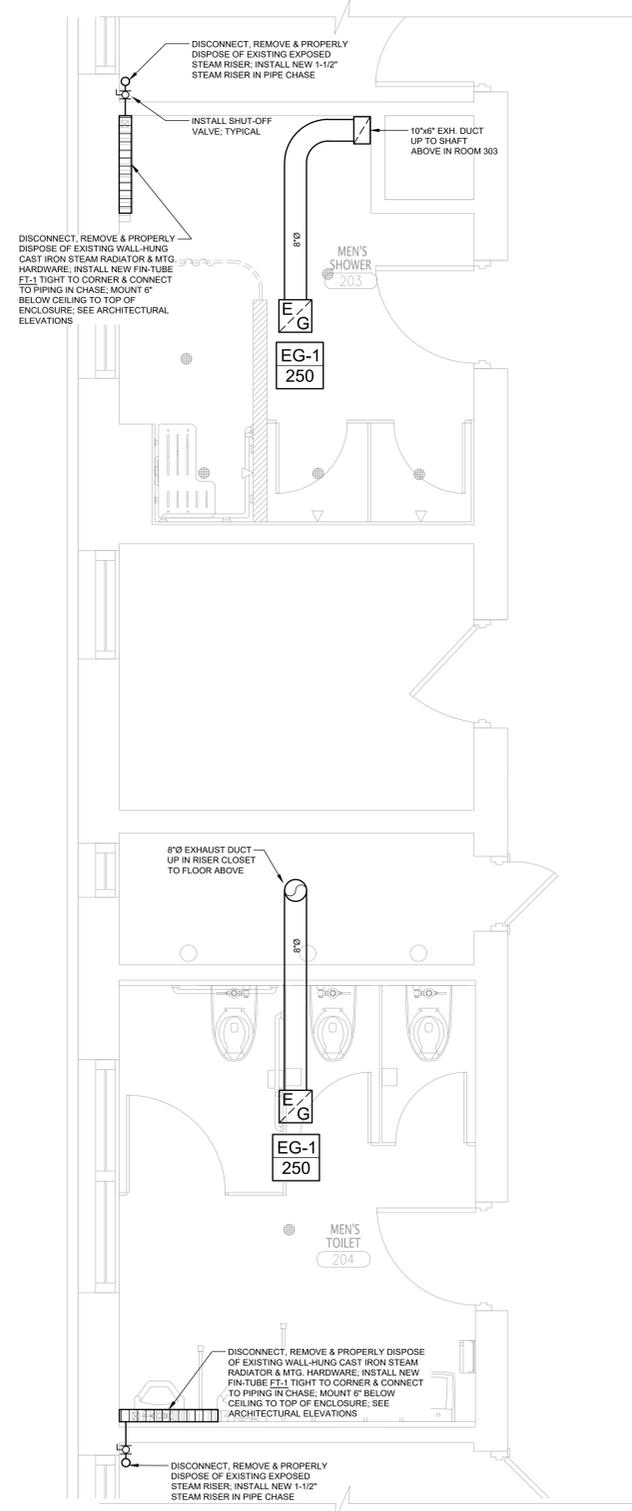


1 SECOND FLOOR TOILET & SHOWER ROOM EXHAUST & HEATING PLAN (RM 203 & 204)
SCALE: 1/2" = 1'-0"

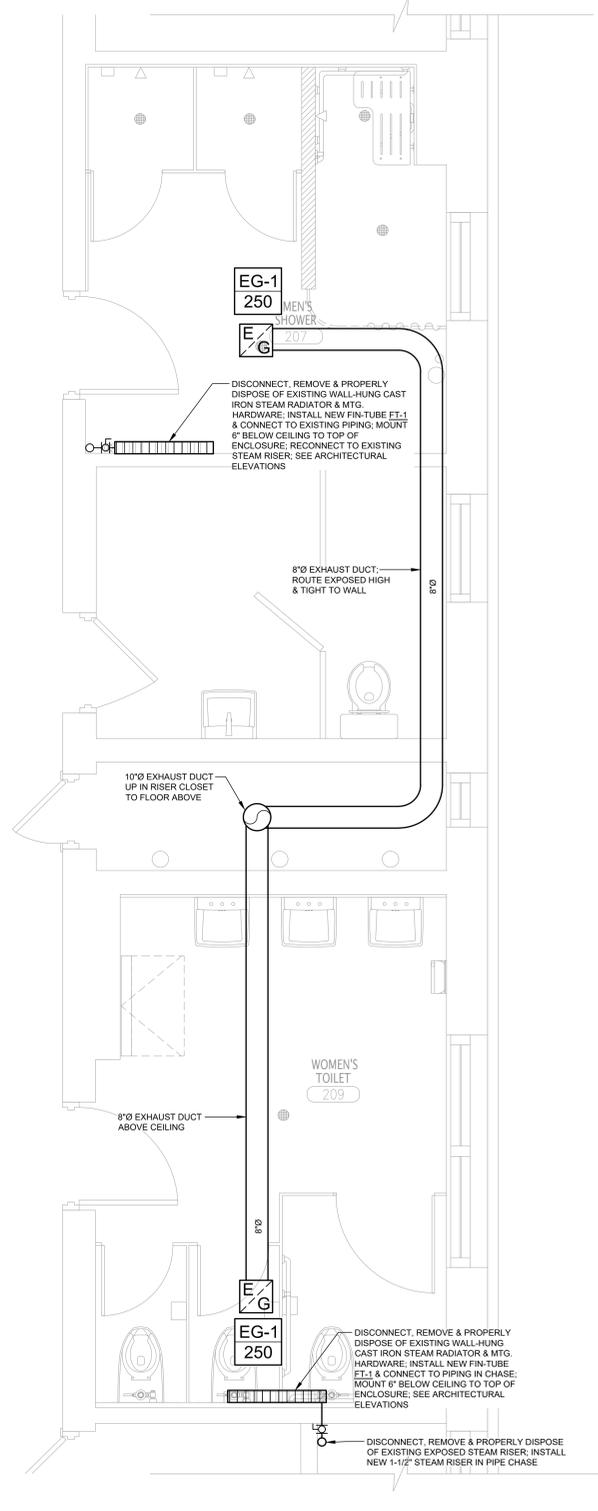


2 SECOND FLOOR TOILET & SHOWER ROOM EXHAUST & HEATING PLAN (RM 207 & 209)
SCALE: 1/2" = 1'-0"

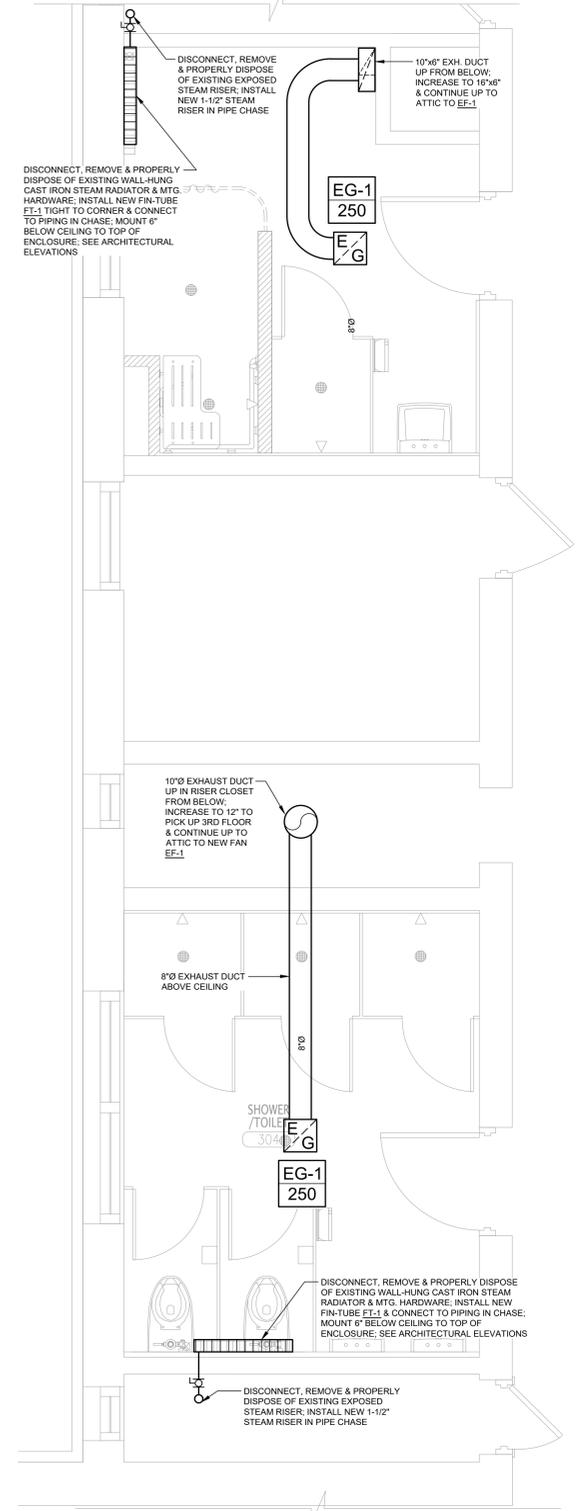

3 THIRD FLOOR TOILET & SHOWER ROOM EXHAUST & HEATING PLAN (RM 303 & 304)
SCALE: 1/2" = 1'-0"

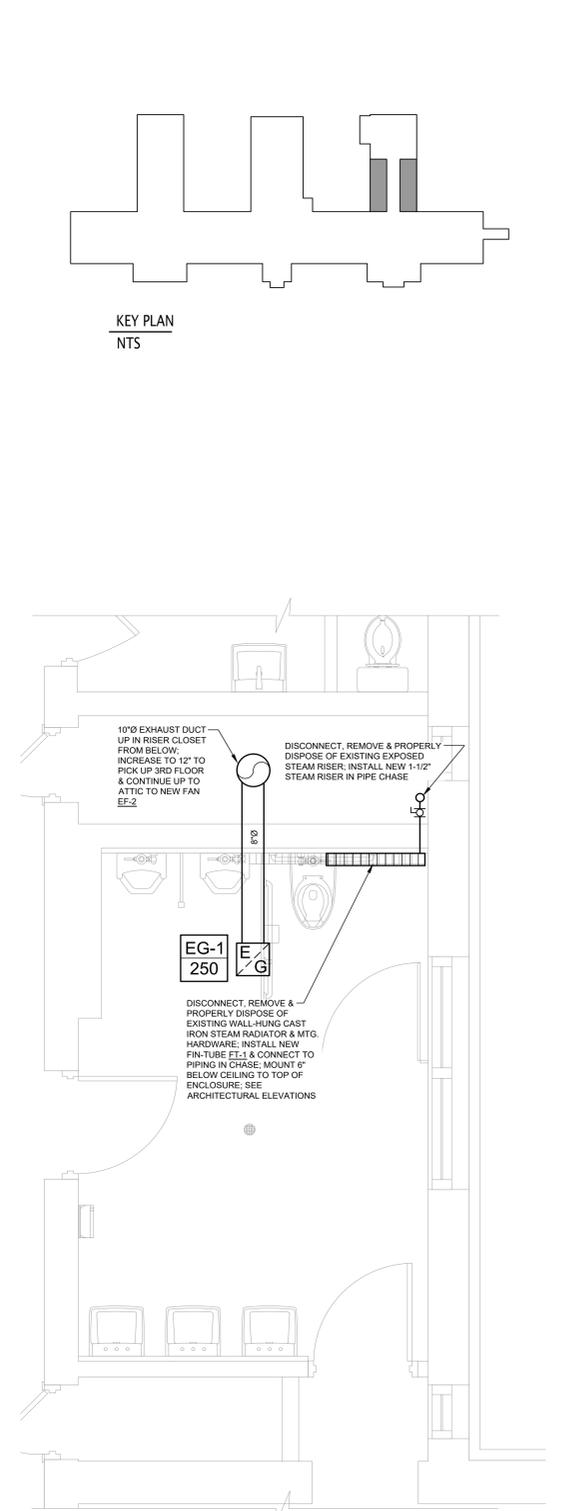

4 THIRD FLOOR TOILET & SHOWER ROOM EXHAUST & HEATING PLAN (RM 305)
SCALE: 1/2" = 1'-0"

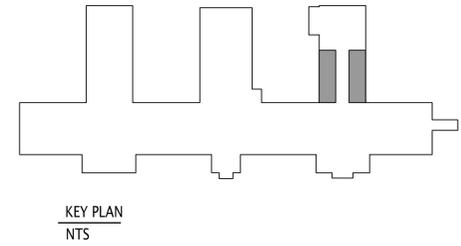

BLAKE ENGINEERING PLLC
1878 COUNTY ROUTE 1, WESTTOWN, NY 10998
TEL: 845-467-9207 FAX: 845-767-5030
MBLAKE@BLAKEENGINEERINGPLLC.COM
MATTHEW G. BLAKE, P.E., LEED AP
NY - 89039 NJ - G1050037 PA - PE079203
MA - 23197 CT - 32283 FL - 85928

ISSUE NO.	ISSUE DATE	DESCRIPTION
1	03-19-2021	ISSUED FOR BID



**ALTERATIONS TO
BUILDING # 51,
EMERGENCY HOUSING
GROUP
38 SEWARD AVENUE
MIDDLETOWN, NY 10940**

**SECOND AND THIRD FLOORS
SHOWER AND TOILET ROOMS
EXHAUST & HEATING PLANS**

PROJECT NO.: 1802-01

DRAWING NO.:

M-200