


THRD FLOOR TOILET ROOM SANITARY DRAINAGE PLAN (ROOM 304)


SCALE: 1/2" = 1'-0"

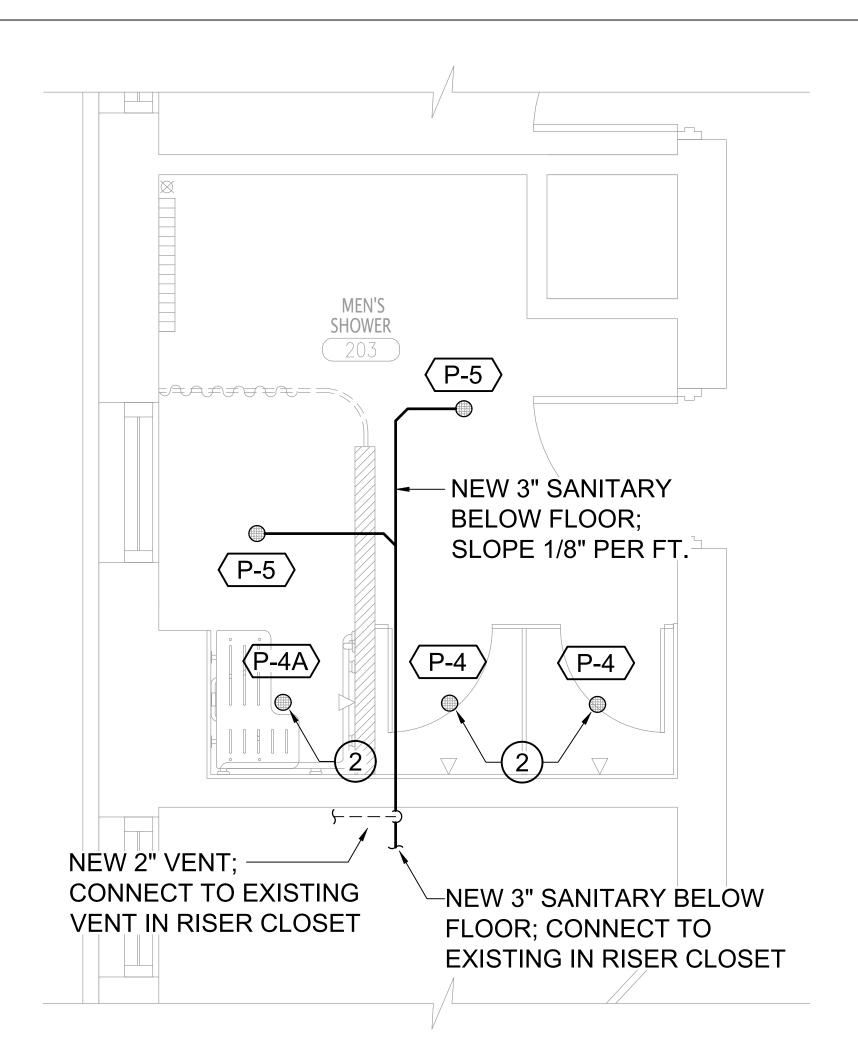


SECOND FLOOR SHOWER ROOM SANITARY DRAINAGE PLAN (ROOM 203)

SCALE: 1/2" = 1'-0"


SCALE: 1/2" = 1'-0"

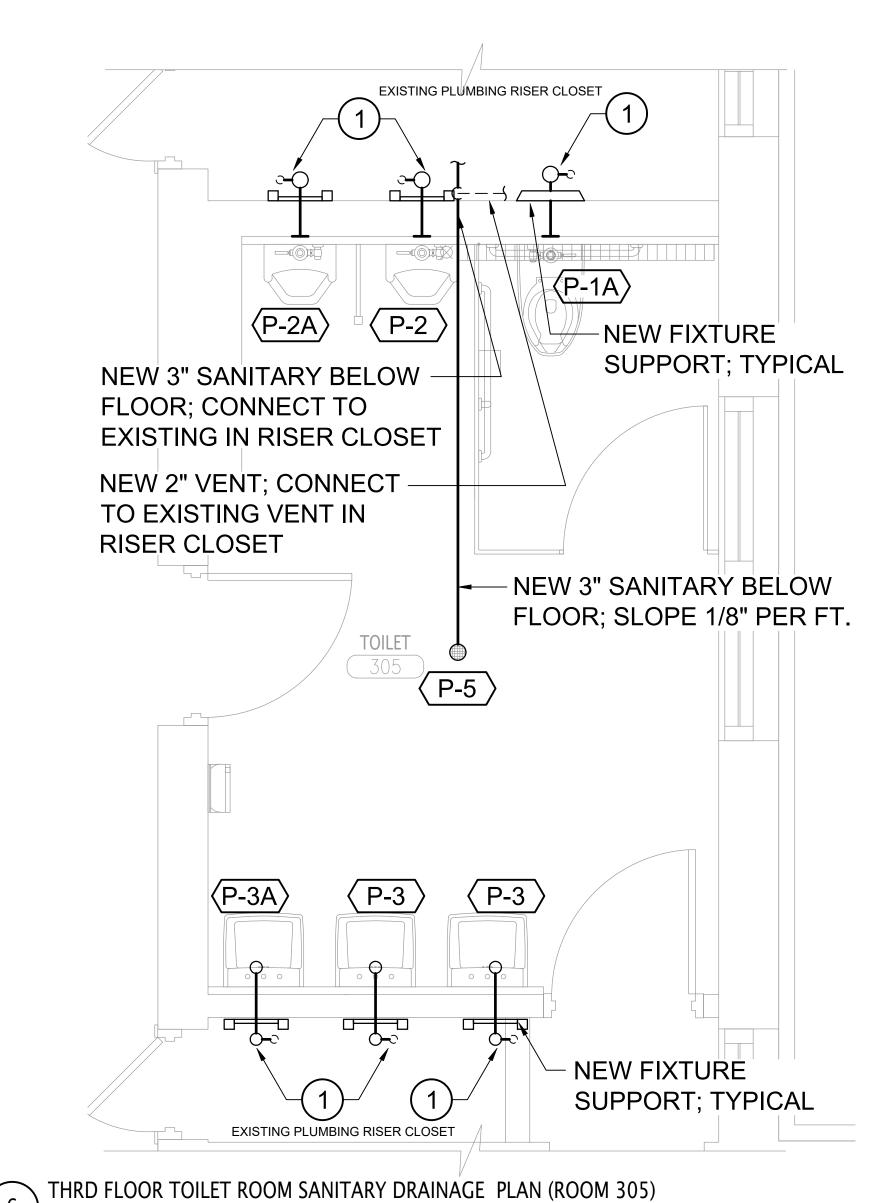

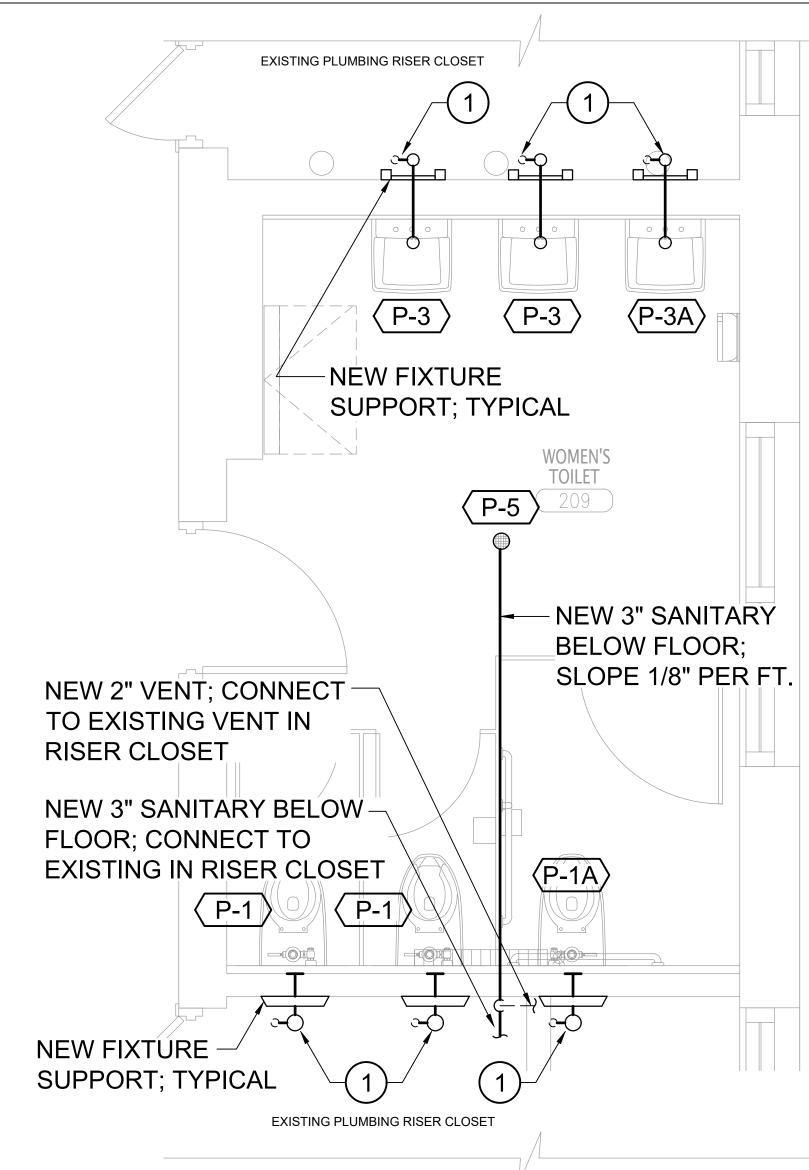


SECOND FLOOR TOILET ROOM SANITARY DRAINAGE PLAN (ROOM 209)

SCALE: 1/2" = 1'-0"

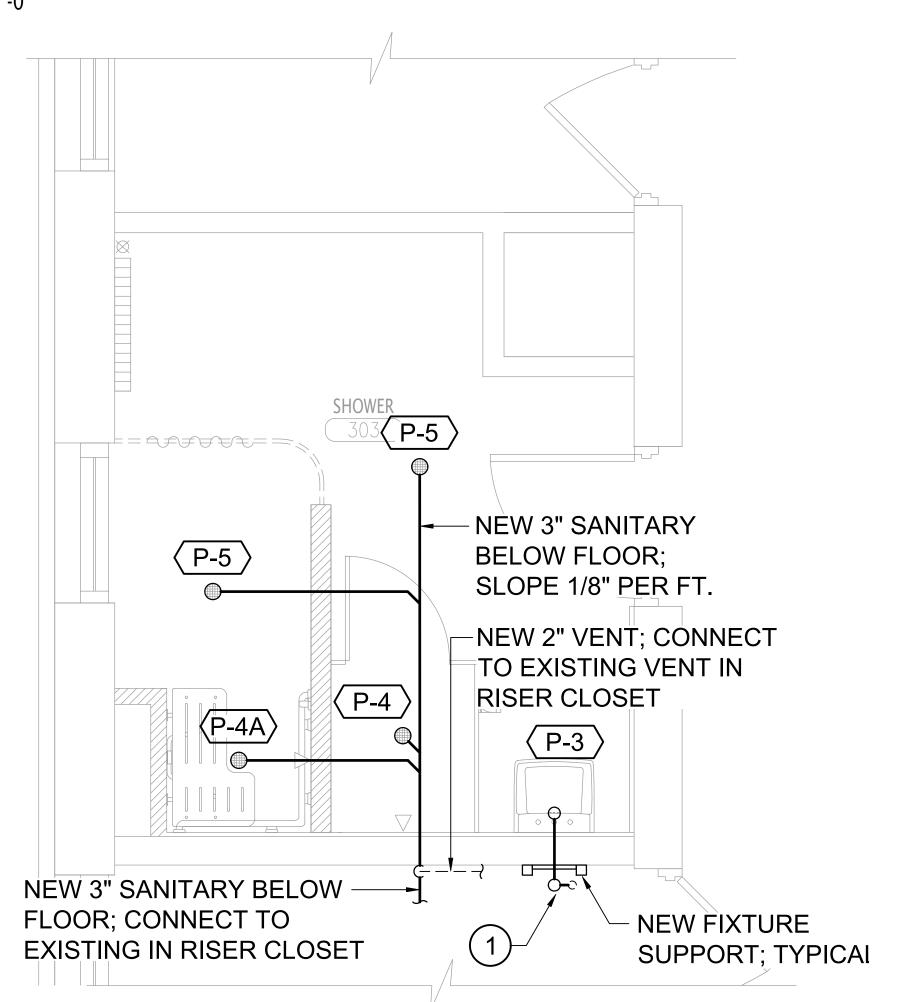


THIRD FLOOR SHOWER ROOM SANITARY DRAINAGE PLAN (ROOM 303)

SCALE: 1/2" = 1'-0"

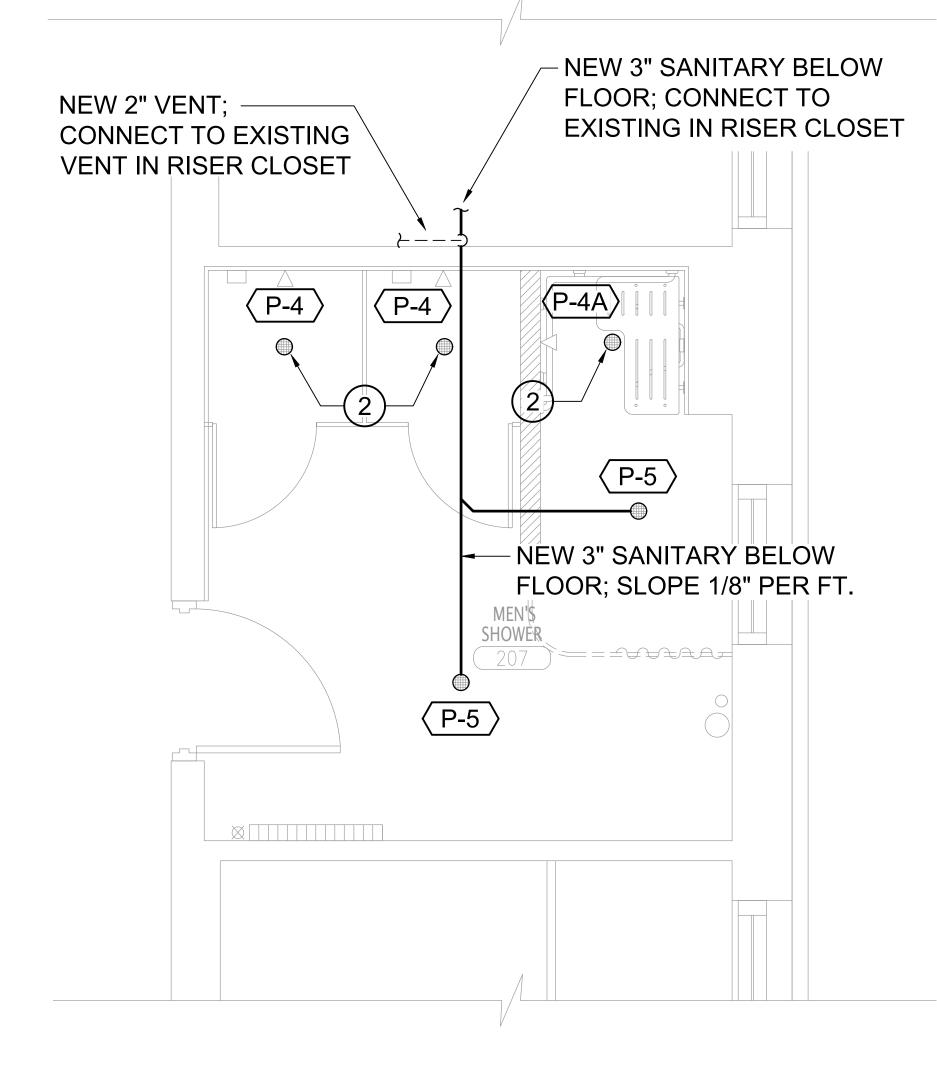

SECOND FLOOR SHOWER ROOM SANITARY DRAINAGE PLAN (ROOM 207)

SCALE: 1/2" = 1'-0"

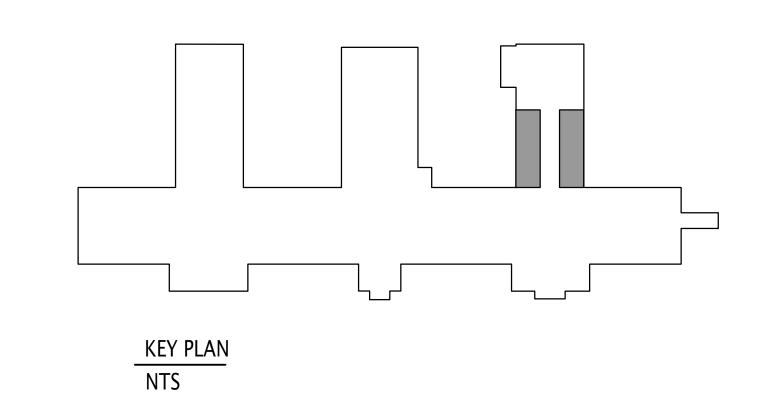

KEYED PLAN NOTES:

1 FURNISH & INSTALL NEW FIXTURE SUPPORT; CONNECT DRAIN & VENT PIPING TO EXISTING IN RISER CLOSET

2 CONNECT NEW SHOWER/FLOOR DRAIN TO EXISTING SANITARY BELOW FLOOR; INSTALL TRAP


NOTE;
PLUMBING CONTRACTOR IS RESPONSIBLE FOR ALL CUTTING, PATCHING & SURFACE RESTORATION ASSOCIATED WITH THEIR WORK



Lothrop Associates LLP Architects
333 Westchester Avenue
White Plains, New York 10604
914-741-1115

White Plains Rochester Red Bank Hartford

MECH'L/ELEC'L/PLUMBING ENGINEERS

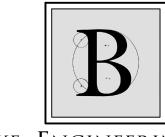



BLAKE ENGINEERING PLLC

1898 COUNTY ROUTE 1, WESTTOWN, NY 10998
TEL: 845-467-9207 FAX: 845-767-5050
MBLAKE@BLAKEENGINEERINGPLLC.COM

MATTHEW G. BLAKE, P.E., LEED AP
NY - 89039 NJ - GE050037 PA - PE079303

MA - 53197 CT - 32283 FL - 85928

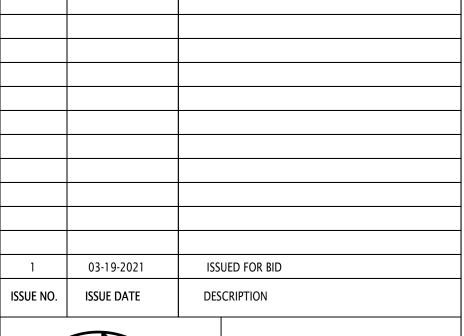

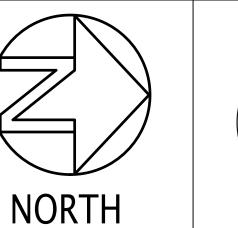



ALTERATIONS TO BUILDING # 51, EMERGENCY HOUSING GROUP 38 SEWARD AVENUE

38 SEWARD AVENUE MIDDLETOWN, NY 10940

SECOND AND THIRD FLOORS
SHOWER AND TOILET ROOMS
SANITARY DRAINAGE PLANS

PROJECT NO.: 1802-01

DRAWING NO.:

P - 200