

ESCUTCHEON
(WHERE REQ'D.
PER SPECS.)
OR DAMMING
MATERIAL
SCHEDULE 40 GALV.
STEEL PIPE SLEEVE
ATTACH SECURELY
TO WALL






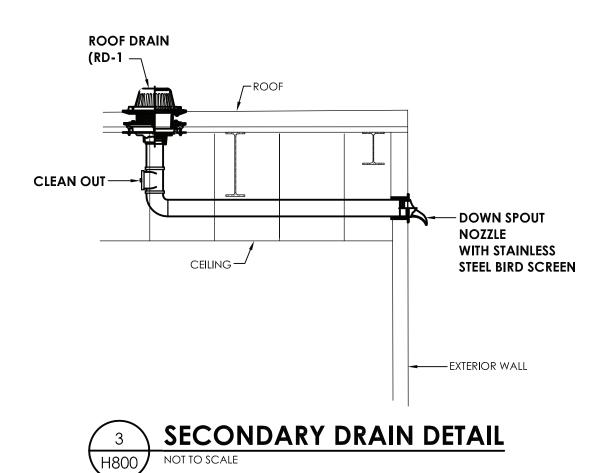


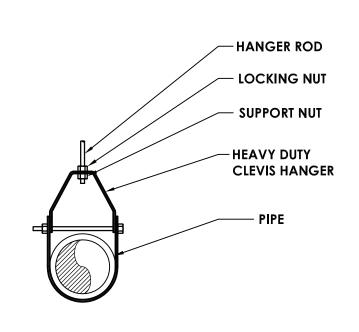




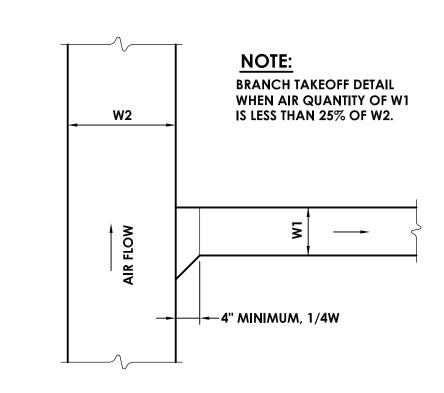

	BRANCH TAKE-OFF DETAIL
H800	NOT TO SCALE

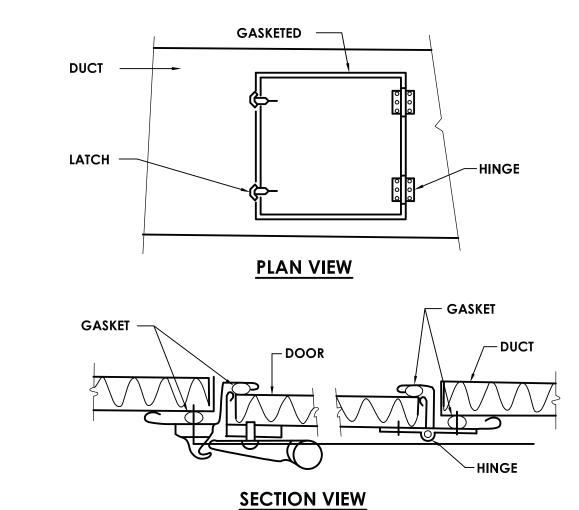



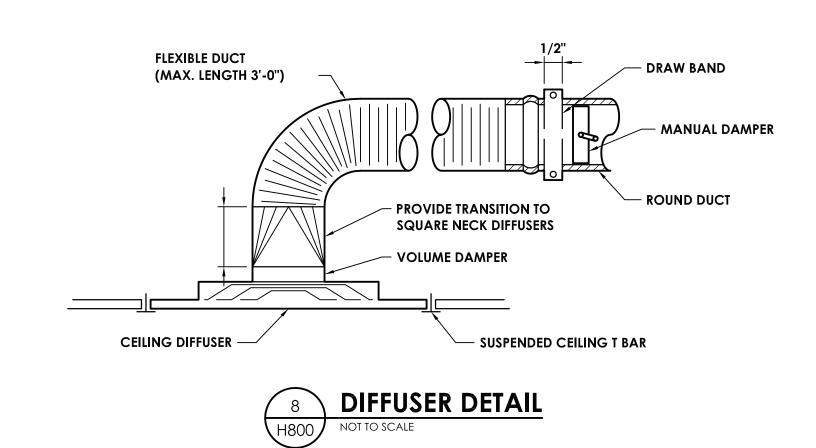


ELECTRIC UNIT HEATER SCHEDULE											
MARK	LOCATION	CAPACITY BTU/H	LENGTH (IN.)	WIDTH (IN.)	HEIGHT (IN.)	WEIGHT (LBS)	ELECTRIC			TYPICAL UNIT MFG	REMARKS:
WARK							VOLTS	PHASE	Watts	& MODEL NO.	KEWAKKS:
EUH-1	STORAGE ROOM S-1	10250	28	10	26	115	208	1	3000	REZNOR - EMC	1, 2
REMARKS: 1. ARCHITECT TO CHOOSE COLOR.											
2. PROVIDE FACTORY MOUNTED AND WIRED DISCONNECT.											


PLUMBING EQUIPMENT & FIXTURE SCHEDULE										
MARK	FIXTURE SAN		DESCRIPTION	MANUFACTURER & MODEL NUMBER	REMARKS					
RD-1	COMBINATION ROOF AND OVER FLOW DRAIN	3	ROOF DRAIN, 12" DIA DOME WITH ADJUSTABLE COLLAR, SUMP RECIEVER, UNDER DECK CLAMP WITH OVERFLOW DRAIN	ZURN Z164	1					
REMARKS:	1. SIZED PER PLAN.				-					

REGISTERS, GRILLES, AND DIFFUSERS											
MARK	APPLICATION	MATERIAL	TYPE	FINISH	FACE SIZE	DESIGN EQUIP.	REMARKS				
D-1	SUPPLY	STEEL	LAY-IN	WHITE	24X24	PRICE SCD					
G-1	RETURN/EA	STEEL	LAY-IN	WHITE	24X24	PRICE PDDR					


OSSINING BROOKSIDE ELEMENTARY OUTSIDE AIR CALCULATIONS										
				TOTAL						
			Occupant	OCCUPANCY	O.A. PER	O.A. PER				
		TOTAL	Density	FOR	PERSON	SQ. FT.	Vbz		Voz=Vot	
Space	Occupancy Classification	SQ. FT.	#/1000sq.ft.	VENTILATION	(CFM)	(CFM)	(CFM)	Ez	(CFM)	Required Exhaust
Classroom 40	Classroom (Ages 9+)	835	35	30	10	0.12	400	0.8	500	
Classroom 41	Classroom (Ages 9+)	835	35	30	10	0.12	400	0.8	500	
Corridor	Corridor	225	0.00	-	0	0.06	14	0.8	17	

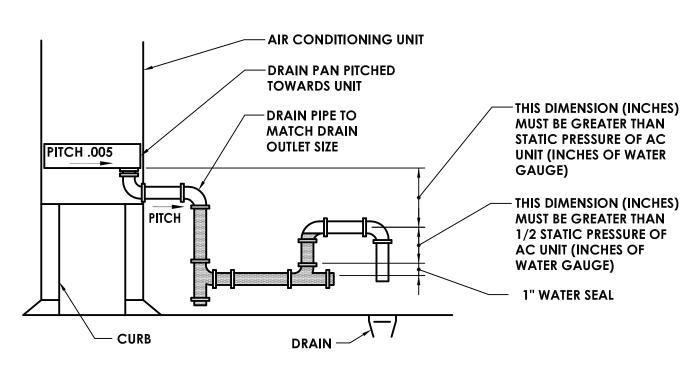



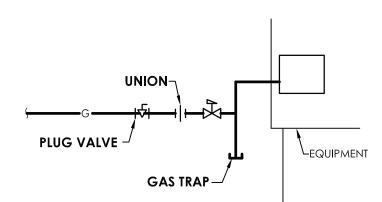





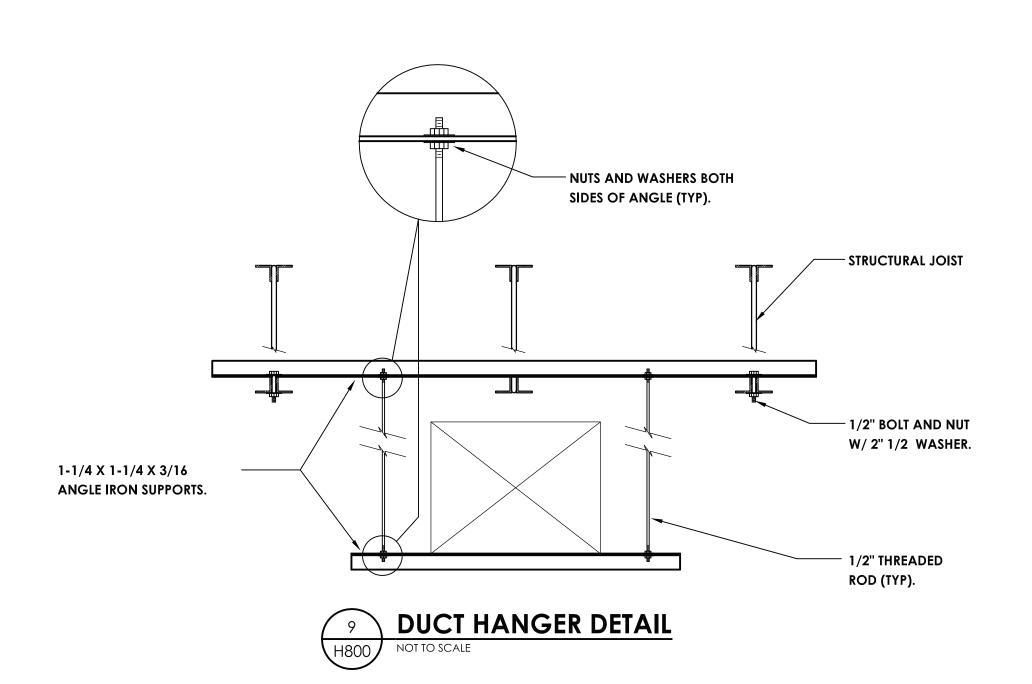



50 FRONT STREET, SUITE 202 NEWBURGH, NEW YORK 12550 TEL (800) 274-9000 FAX (845) 567-9614

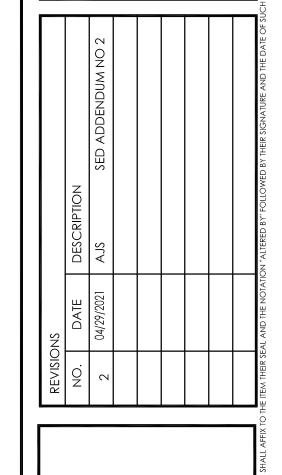

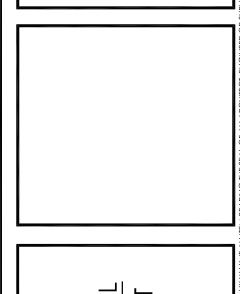

SCHOOL DISTRICT

SROOKSIDE ELEMENTARY SCHOOL

CLASSROOM ADDITION PROJECT

SED# 66-14-01-03-0-001-022

DATE DRAWN CHECKED
12/18/20 BKM AJS

SCALE NTS

SHEET TITLE

HVAC SCHEDULES AND
DETAILS

PROJECT NUMBER

BES H800