

LAY-IN LIGHTING FIXTURES	
RECESSED LIGHTING FIXTURES	
SUSPENDED LIGHT FIXTURES	
SURFACE MOUNTED LIGHT FIXTURES	
EXIT SIGN	
MECHANICAL SUPPLY DIFFUSERS	
MECHANICAL RETURN AIR GRILLES	
MECHANICAL EXHAUST FANS	

1. ALL DIMENSIONS ARE TO CENTERLINE OR TO FACE OF FINISHED WALL U.N.O.
2. PROVIDE ACCESS PANELS AT ALL CONCEALED VALVES, BREAKERS, SERVICE POINTS, ETC.
3. G.C. TO PROVIDE BLOCKING FOR ALL ACCESSORIES AND BUILDING ITEMS THAT ARE CEILING MOUNTED, INCLUDING WOOD TRIM AND MILLWORK.
4. COORDINATE MECHANICAL, ELECTRICAL AND SPRINKLER PLANS WITH OVERALL CEILING PLAN. NOTIFY ARCHITECT OF CONFLICTS WHICH CANNOT BE RESOLVED.
5. CENTER SPRINKLER HEADS, SMOKE DETECTORS, DOWNLIGHTS, AND ALL CEILING-MOUNTED ITEMS IN ACOUSTICAL TILES. IN HARD CEILINGS, CENTER IN SPACE OR LOCATE ACCORDING TO PLANS.
6. PAINT CEILING REGISTERS, GRILLES, AND ACCESS PANELS TO MATCH ADJACENT CEILING COLOR.
7. SEE SHEET A702 FOR GUEST ROOM REFLECTED CEILING PLANS.

**11 REFLECTED CEILING LEGEND**  
A701 NO SCALE

**21 REFLECTED CEILING NOTES**  
A701 NO SCALE


**A NEW 108-ROOM COURTYARD BY MARRIOTT HOTEL & SUITES**  
Turner Road  
Woodbury, New York  
location #12121

for  
**RAINBOW ENTERPRISES**  
4758 Highway 28  
Cooperstown, NY

REVISION DATES

UNAUTHORIZED ALTERATIONS OR ADDITIONS TO THIS DRAWING ARE A VIOLATION OF STATE EDUCATION LAW ARTICLES 145 AND 147.  
THIS DRAWING IS AN INSTRUMENT OF SERVICE FOR RAINBOW ENTERPRISES, AND MAY NOT BE REPRODUCED WITHOUT THE EXPRESS CONSENT OF THE OWNER AND THE ARCHITECT

DRAWING TITLE  
**TYPICAL FLOOR REFLECTED CEILING PLAN**  
DATE  
MARCH 1, 2021  
PROJECT NUMBER  
17971  
SHEET NUMBER  
**A701**

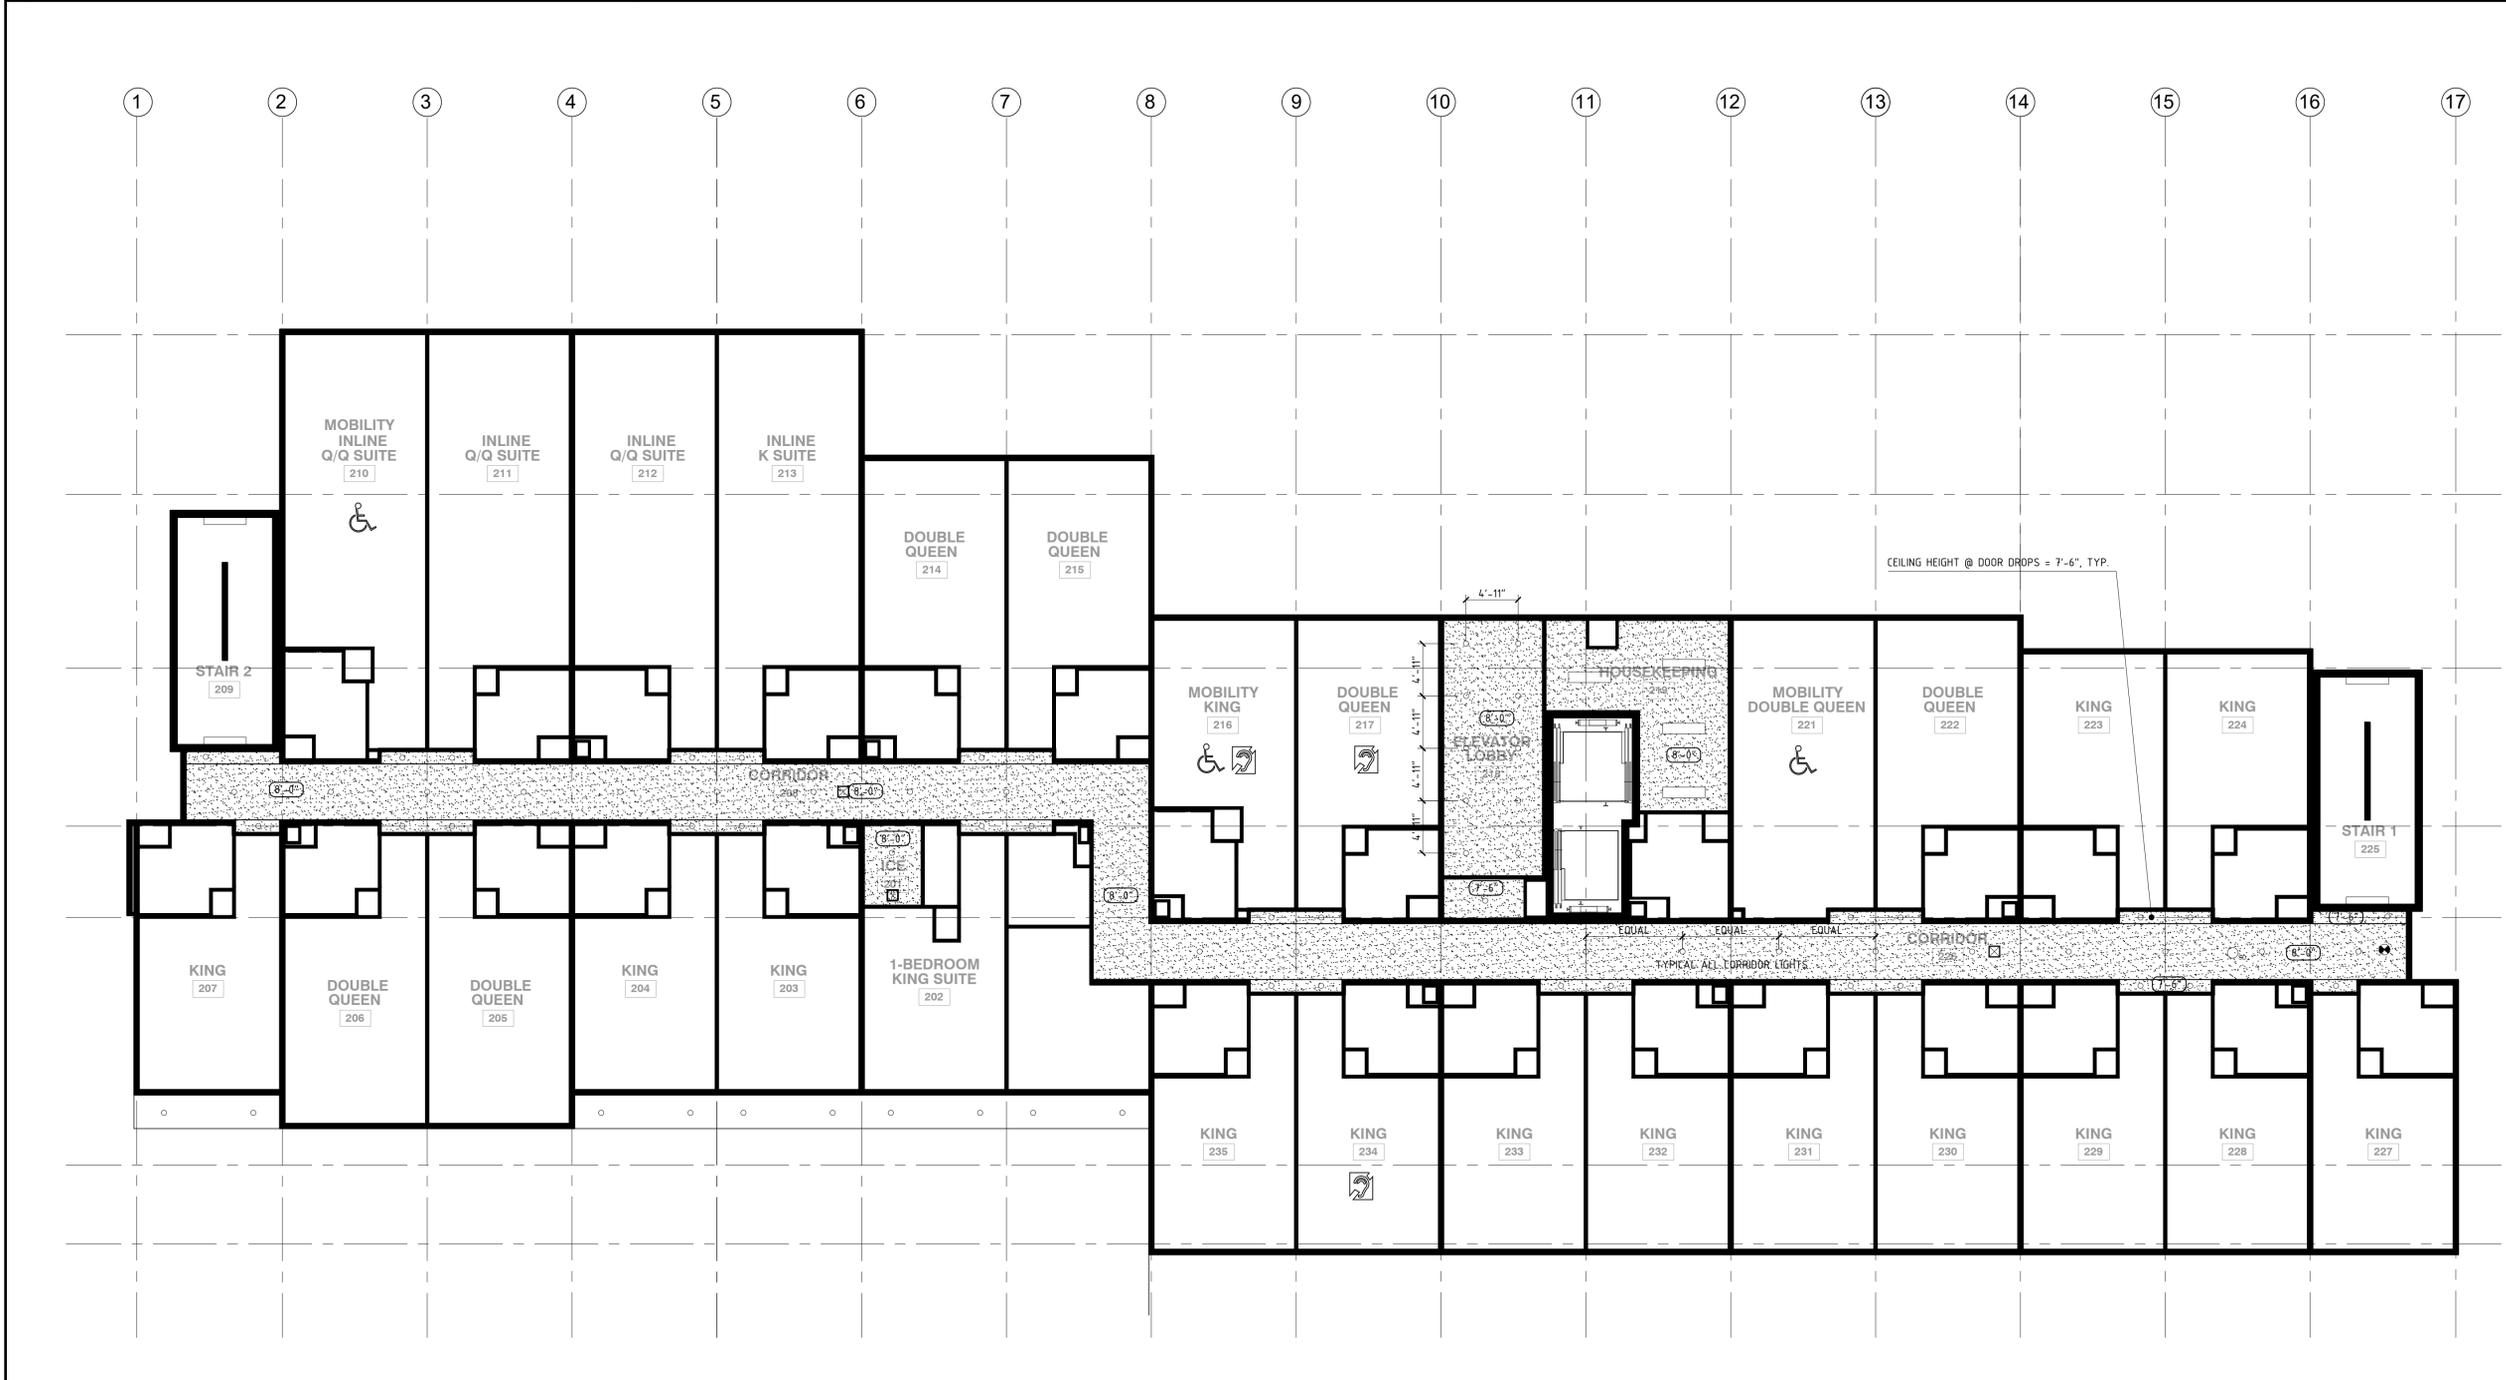

**14 SECOND FLOOR REFLECTED CEILING PLAN (THIRD - FIFTH FLOORS SIMILAR)**  
A701 1/8" = 1'-0"