


1 THIRD FLOOR PLAN - DEMOLITION SCALE: 1/8"=1'-0"

<u>KEYED NOTES - DEMOLITION</u>

FOR NEW WORK.

The remove existing grilles and diffusers as shown and discard. Prepare for New Work, see architectural drawings for exact LOCATIONS.

REMOVE FIN TUBE COVERS AND DISCARD. VACUUM AND CLEAN, WIRE BRUSH EXISTING FIN TUBE AS REQUIRED. PREPARE FOR NEW WORK REMOVE ALL DUCT INSULATION ON SUPPLY MAIN DUCTWORK, BRANCHES, AND DROPS TO DIFFUSERS AND REGISTERS. PREPARE

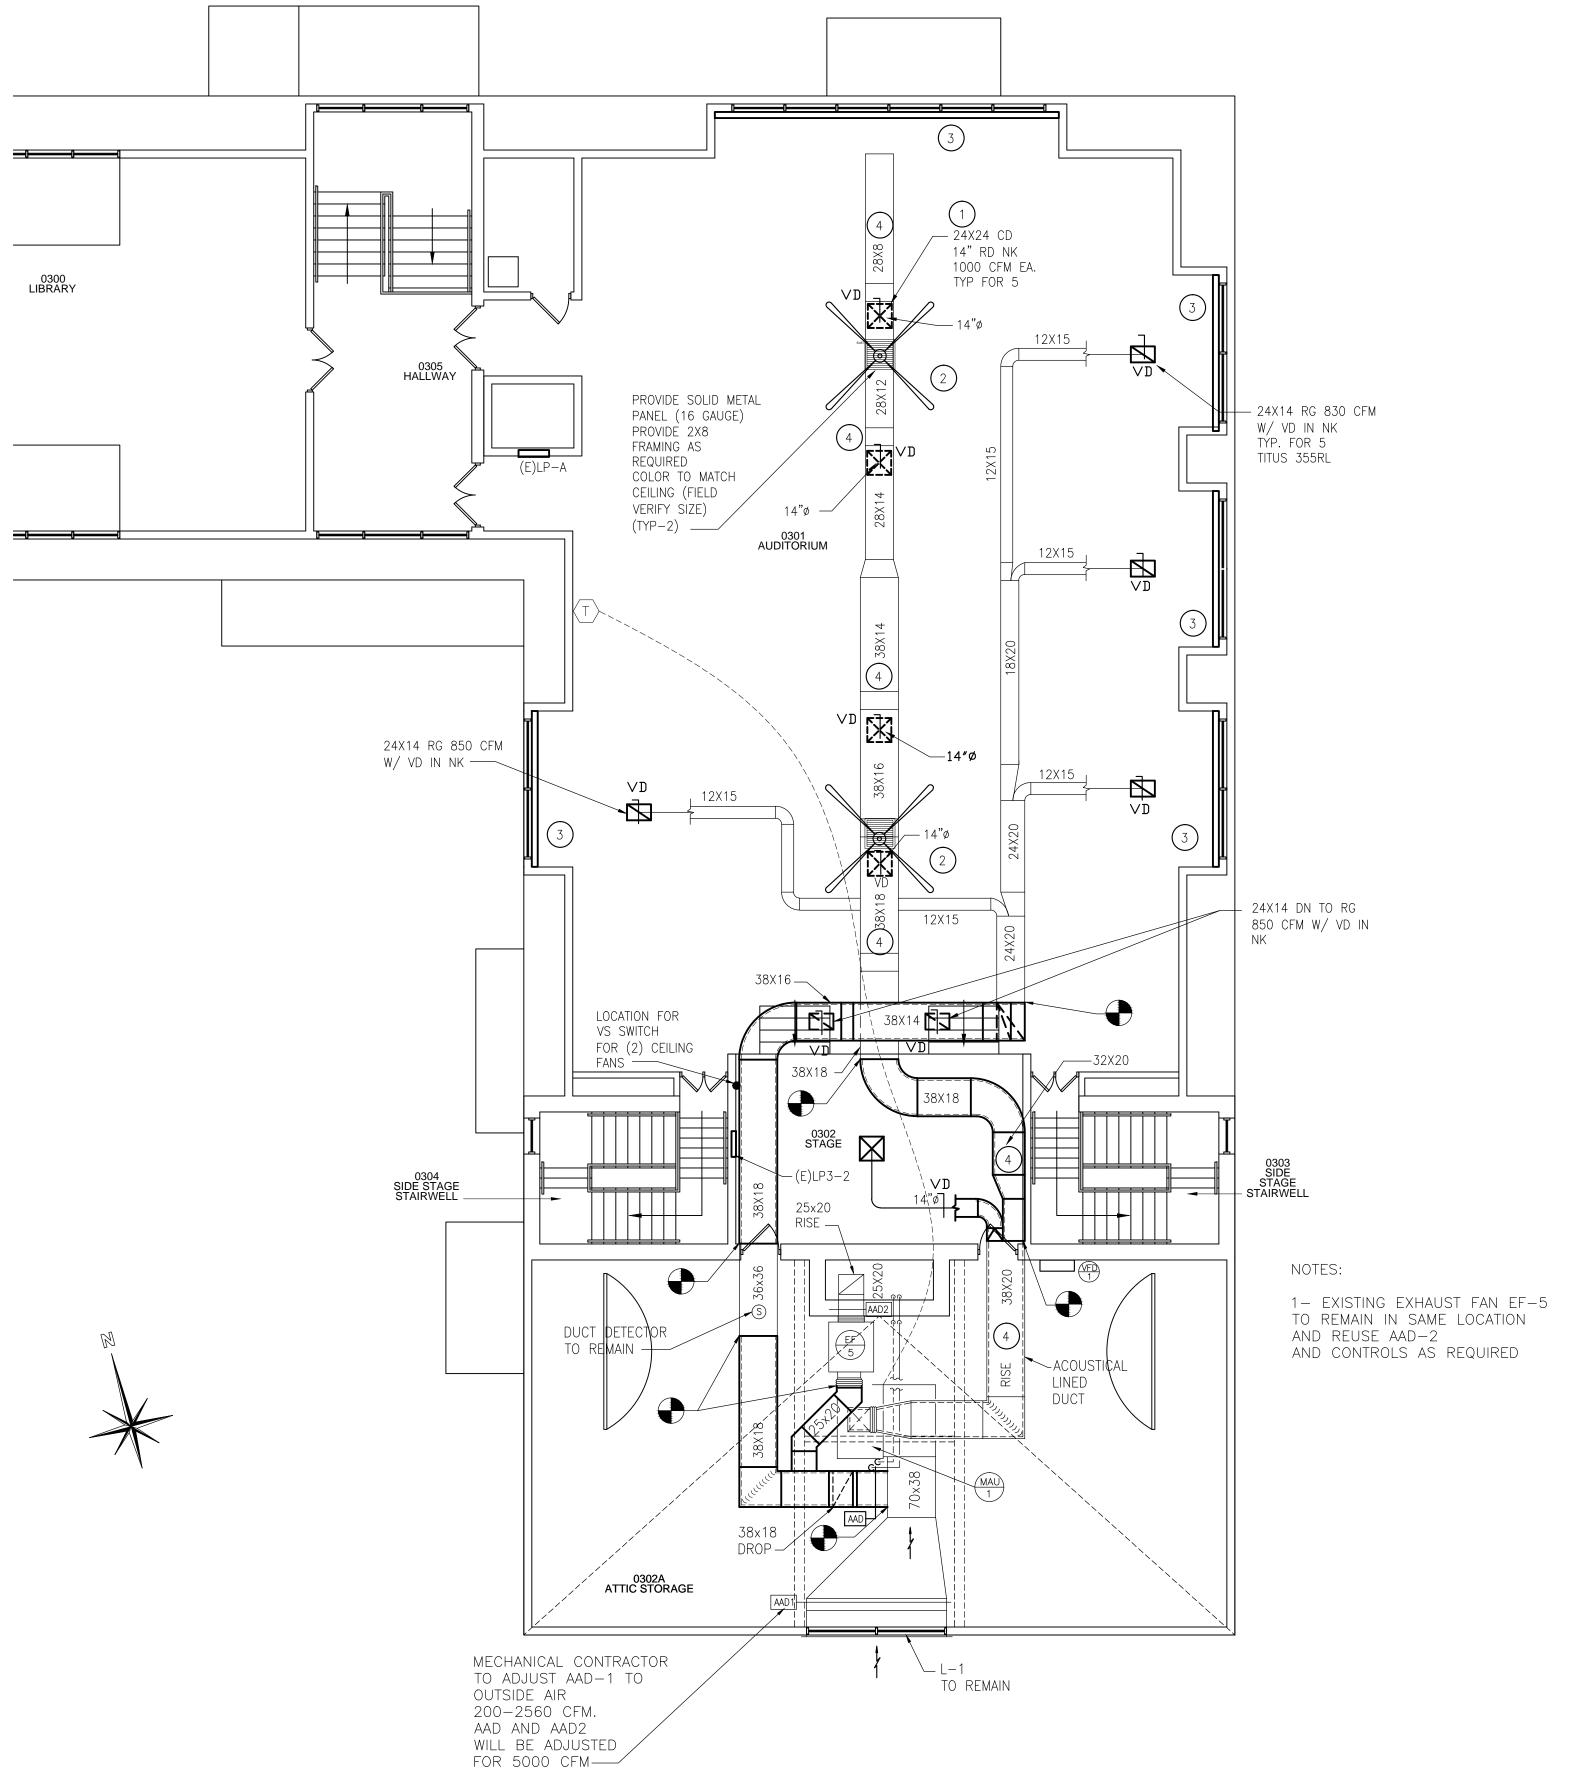

THIRD FLOOR PLAN - NEW WORK SCALE: 1/8"=1'-0"


<u>KEYED NOTES — NEW WORK:</u>

PROVIDE NEW SUPPLY DIFFUSERS TITUS TDCA 24x24, ROUND NECK, B4, #26 WHITE, BORDER TYPE 1 SURFACE MOUNT, AG-95 BLADE DAMPER AND EG EQUALIZING GRID.


2 PROVIDE 2 CEILING FANS WITH ALL APPURTENANCES. BIG ASS FAN 16 60" BRONZE OR APPROVED EQUAL.

3 PROVIDE NEW FIN TUBE COVERS AS SHOWN. SEE DETAILS ON M-500. (COLOR BY OWNER)

4 MECHANICAL CONTRACTOR TO PROVIDE NEW DUCT INSULATION ON SUPPLY MAIN DUCTWORK, BRANCHES, AND DROPS TO ALL DIFFUSERS AND REGISTERS. SEAL/TAPE ALL SEAMS.

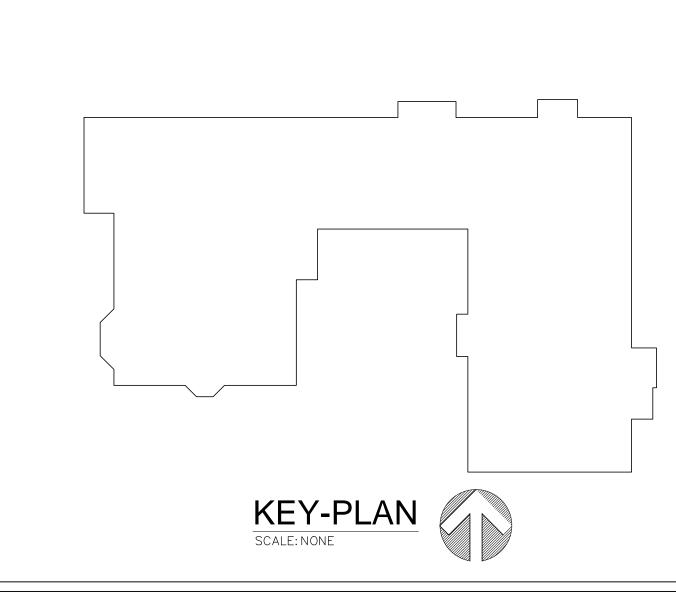

CONSULTANT(S):

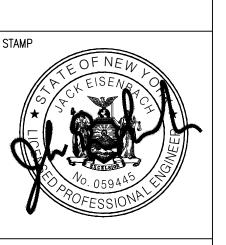

YONKERS PUBLIC SCHOOLS
BUILDING RENOVATIONS AND
SITEWORK AT
SCHOOL 9
53 FAIRVIEW STREET, YONKERS N.Y. 10703 E&R PROJECT NO. Y170901

YPS NO.

ISSUE FOR ADDENDUM 3 FOR BID 6569A 1.20.2021 REVISION DATE BY ISSUED FOR BID 10.20.2020 DRAWN BY JMJ

CHECKED BY JIE SHEET SIZE ARCH E1 30" x 42" AS NOTED

SHEET TITLE

FLOOR PLAN -DEMOLITION AND NEW WORK

M-101