

**PARTITION RATING GRAPHICS:**

PARTITIONS REQUIRED TO BE SMOKE RESISTANT, FIRE RESISTANT, OR BOTH FIRE AND SMOKE RESISTANT ARE SHOWN GRAPHICALLY ON PLANS WITH HATCH PATTERNS.

PARTITION RATING GRAPHIC DESIGNATION:	PRIORITY
	4 HR FIRE BARRIER - 1 HIGHEST
	3 HR FIRE BARRIER - 2
	2 HR FIRE & SMOKE BARRIER - 3
	2 HR FIRE BARRIER - 3
	1 HR FIRE & SMOKE BARRIER - 4
	1 HR FIRE BARRIER - 4
	1 HR FIRE BARRIER/SHAFT - 4
	SMOKE PARTITION (NON RATED) - 5 LOWEST
	NON RATED - 5 LOWEST

**DEDUCT ALTERNATIVE NOTES**

(DEDUCTIVE ALTERNATIVES ARE CASCADING AND MUST BE EXERCISED IN THE ORDER PRESENTED) FOR A DETAILED DESCRIPTION OF EACH DEDUCTIVE ALTERNATE REFER TO COVER SHEET G1000.

DEDUCT ALTERNATIVE #9: ELIMINATE LARGE PORCH

DEDUCT ALTERNATIVE #11: ELIMINATE SMALL PORCH-B

**LIGHTING FIXTURES LEGEND**


	2x4 FIXTURE - RECESSED, SURFACE, OR PENDANT MOUNTED - TYPE AS SPECIFIED
	2x4 LIFE SAFETY BRANCH FIXTURE - RECESSED, SURFACE, OR PENDANT MOUNTED - TYPE AS SPECIFIED
	1x4 FIXTURE - RECESSED, SURFACE, OR PENDANT MOUNTED - TYPE AS SPECIFIED
	1x4 LIFE SAFETY BRANCH FIXTURE - RECESSED, SURFACE, OR PENDANT MOUNTED - TYPE AS SPECIFIED
	LIGHTING FIXTURE - RECESSED OR SURFACE MOUNTED - TYPE AS SPECIFIED
	LIFE SAFETY BRANCH LIGHTING FIXTURE - RECESSED OR SURFACE - TYPE AS SPECIFIED
	LIGHTING FIXTURE - PENDANT MOUNTED - TYPE AS SPECIFIED
	LIFE SAFETY BRANCH LIGHTING FIXTURE - PENDANT - TYPE AS SPECIFIED
	WALL MOUNTED - TYPE AS SPECIFIED
	LIFE SAFETY BRANCH WALL FLUSH MOUNTED - TYPE AS SPECIFIED
	EXIT SIGN - CEILING MOUNTED - TYPE AS SPECIFIED
	EXIT SIGN - WALL MOUNTED - TYPE AS SPECIFIED
	SINGLE-POLE, 3-WAY SWITCHES (48" AFF)
	LOCAL WALL DIMMER SWITCH (48" AFF)
	FAN SWITCH (48" AFF)
	WALL MOUNTED OCCUPANCY SENSOR SWITCH: DUAL TECHNOLOGY (PASSIVE INFRARED/ULTRASONIC)
	CEILING MOUNTED DAYLIGHT SENSOR
	CEILING MOUNTED OCCUPANCY/VACANCY SENSOR: DUAL TECHNOLOGY (PASSIVE INFRARED/ULTRASONIC)
	ROOM CONTROLLER (REFER TO PLANS)
	EMERGENCY RELAY (REFER TO PLANS)

**GENERAL NOTES**


- CONTRACTOR SHALL BE RESPONSIBLE FOR IDENTIFICATION OF ALL RATED WALLS, CEILING AND SLABS AND THEIR SPECIFIED RATING ON THE ARCHITECTURAL DRAWINGS. ALL DEVICES AND MATERIALS SHALL MEET THE UL RATING OF THE RATED WALLS, CEILING AND SLABS ASSEMBLY. CONTRACTOR SHALL PROVIDE AN ASSEMBLY INSTALLED IN ACCORDANCE WITH THE RATED APPLICATION.
- ALL OCCUPANCY/VACANCY SENSORS SHALL TURN OFF WITHIN 20 MINUTES OF THE SPACE BECOMING UNOCCUPIED.
- OCCUPANCY SENSORS SHALL FAILSAFE "ON".
- ALL COMMON AREAS SHALL BE CONTROLLED VIA LCP - LIGHTING CONTROL PANEL FOR DIMMING CONTROL OF THE LIGHTING. FOR SAFETY REASONS, THE FACILITY COMMON AREAS SHALL REMAIN "ON" 24/7. THE LIGHTING CONTROL PANEL WILL DIM THE LIGHTING DOWN TO 30% WHEN NO MOTION IS DETECTED IN THE SPACE. WHEN CEILING SENSORS DETECT MOTION, THE LIGHTING WILL DIM UP TO 100%.
- WHERE MULTIPLE SWITCHES ARE SHOWN AT THE SAME LOCATION, THEY SHALL BE GANGED TOGETHER WITH A COMMON GANG FACEPLATE.
- ALL LINE VOLTAGE WALL SWITCHES SHALL BE A PUSH BUTTON TYPE UNLESS OTHERWISE NOTED.
- FOR EACH EXIT SIGN, CONTRACTOR SHALL PROVIDE UN-SWITCHED HOT FROM LIFE SAFETY CIRCUIT.
- FIXTURES INDICATED WITH A 'F' SHALL BE CONTROLLED VIA 'DS' DAYLIGHT SENSOR. FIXTURE SHALL BE MOUNTED AT 10'-0" ABOVE FINISH FLOOR.
- FIXTURE 'Q' SHALL AIM TO THE ART ON WALL. COORDINATE EXACT LOCATION AND AIMING WITH ARCHITECT AND OWNER.
- WALL SCONCES INDICATED WITH AN 'H' SHALL BE MOUNTED 58" AFF AND VANITY FIXTURES INDICATED WITH A 'B' SHALL BE MOUNTED 90" AFF UNLESS OTHERWISE NOTED.

**KEYNOTES**

- MOUNT SCONCE AT EVERY UNIT ENTRY DOOR AT THE LATCH SIDE BY 10" OFF CENTER FROM THE EDGE OF THE DOOR.

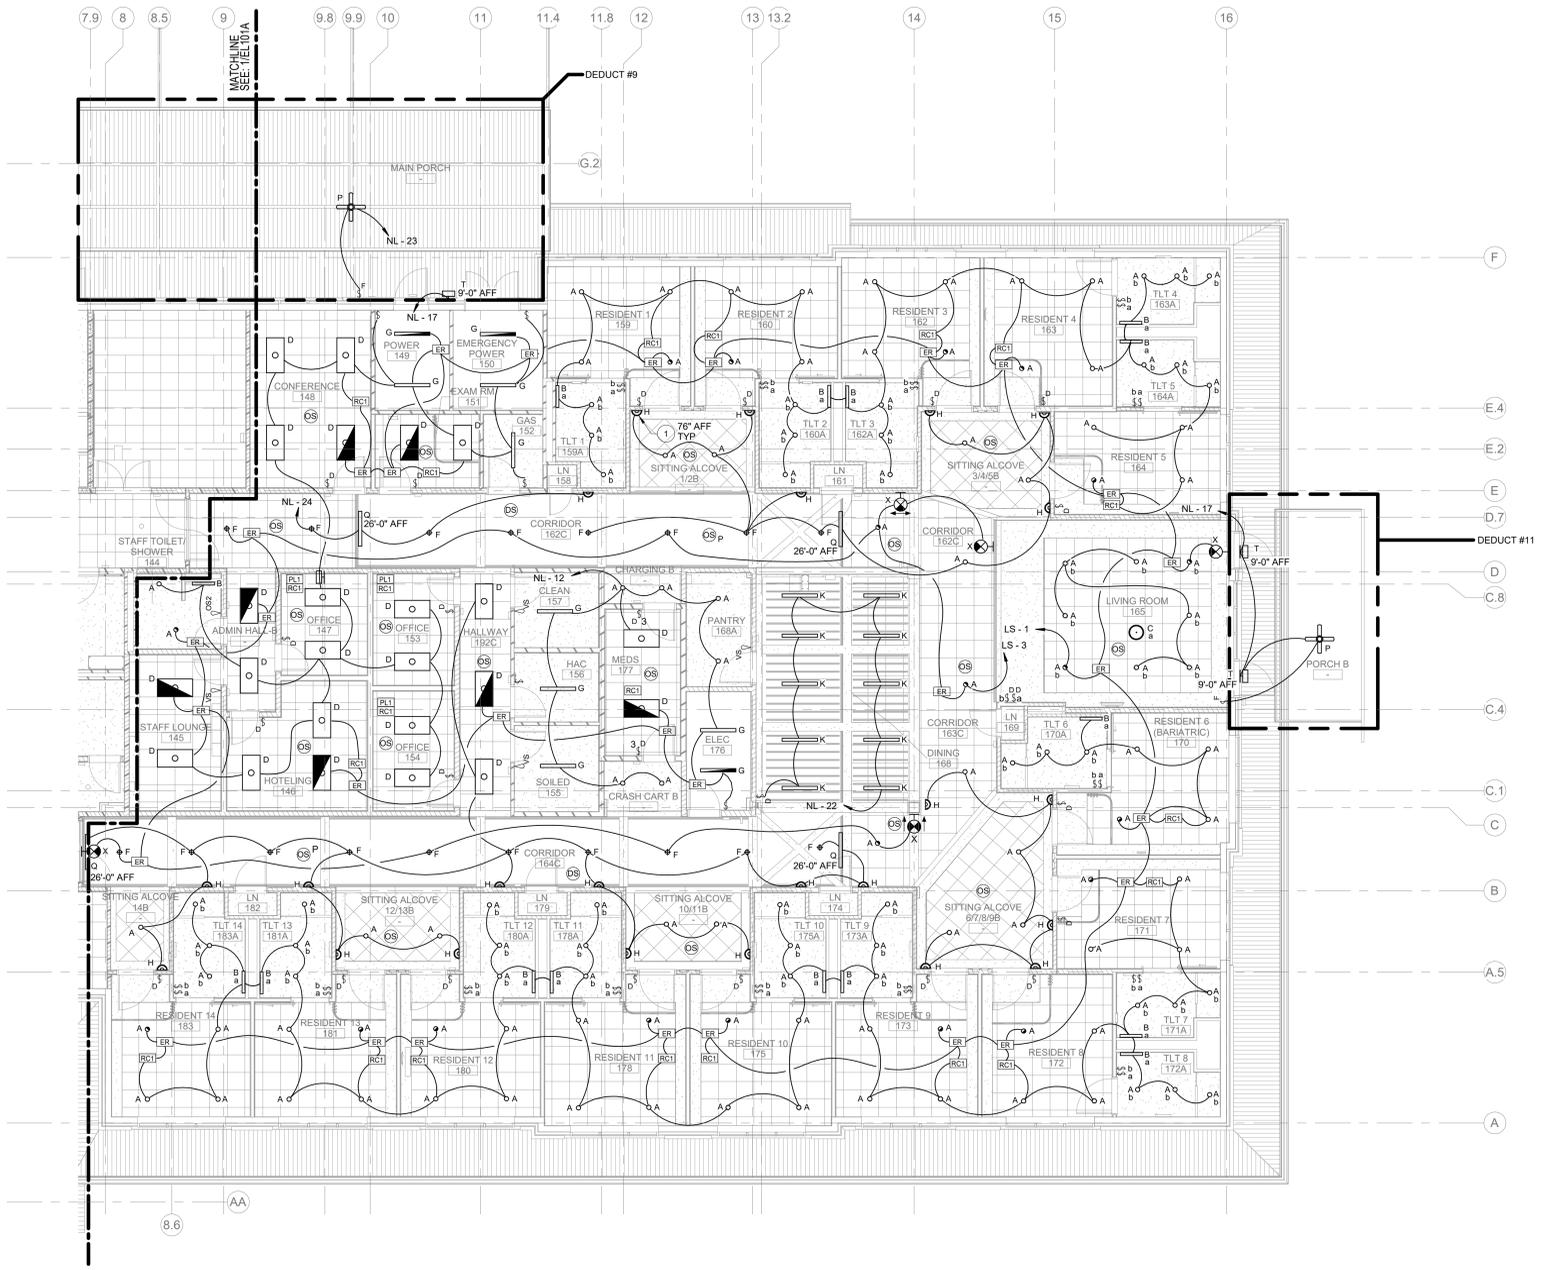

**1 LIGHTING FLOOR PLAN - LEVEL 1 - AREA B**  
1/8" = 1'-0"

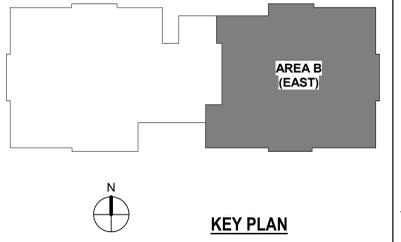

6/2/2022 2:05:54 AM  
BIM:360:620-334 New Community Living Center/15571\_MEP\_VA Montrose CLC (R20)14

Revisions:	Date:

**CONSULTANT**

 Landscape Architect 416 North Toole Avenue Tucson, AZ 85711 (520) 622-9565 Josh Orth, P.L.A.	 Protective Design Specialist 240 West 53th St, Suite 1004 New York, NY 10001 (212) 967-4890 Corinne Tan, SE	 Structural 315 West James Street, Suite 102 Lancaster, PA 17603 (717) 481-2991 Jason Vannoy, SE, PE	 MEP 550 North Rex Street, Suite 203 Tampa, FL 33609 (813) 289-4700 Nicholas Stephenson, PE
--	---	---	--

**ARCHITECT/ENGINEER OF RECORD**

A/E:  
**TRIPLE C - The A/E Group**  
 201 E. Jefferson Street, Suite 200  
 Syracuse, NY 13202  
 (315) 484-9568  
 Mat Perkins

**TRIPLE C - THE A&E GROUP**  
 A MULTI-DISCIPLINE COMPANY

**STAMP**

STATE OF NEW YORK  
 REGISTERED PROFESSIONAL ENGINEER  
 MAT PERKINS  
 05/09/2022

Office of  
 Construction  
 and Facilities  
 Management

**VA** U.S. Department  
 of Veterans Affairs

Drawing Title  
 LIGHTING FLOOR PLAN - LEVEL 1 - AREA B

Approved:

Phase  
**ISSUED FOR CONSTRUCTION**

**FULLY SPRINKLERED**

Project Title  
**NEW COMMUNITY LIVING CENTER**

Location  
 2094 Albany Post Road, Montrose, NY 10548

Issue Date  
 05/09/2022

Checked  
 DK

Drawn  
 SC

Project Number  
 620-334

Building Number  
 CLC

Drawing Number  
**EL101B**