

SYMBOL KEY

	EXISTING PIPING TO REMAIN
	EXISTING PIPING TO BE REMOVED
	NEW PIPING
	1" ARM-OVER TO NEW SPRINKLER FROM EXISTING 1" OUTLET
	CONNECT TO EXISTING PIPE AND/OR FITTING
	EXISTING SPRINKLER AND ARM-OVER TO BE DEMOLISHED BACK TO OUTLET ON BRANCH LINE UNLESS SHOWN OTHERWISE
	ORDI5.6/SR
	ORDI5.6/SR
	ORDI5.6/QR
	INTI5.6/QR
	APPROXIMATE CENTER LINE ELEVATION OF EXISTING PIPE ABOVE FINISHED FLOOR
	RECOMMENDED CENTER LINE ELEVATION OF NEW PIPE ABOVE FINISHED FLOOR
	RISE FROM LEFT TO RIGHT AND DROP FROM RIGHT TO LEFT
	NOT IN SCOPE

UNDERGROUND PIPING NOTE
ALL UNDERGROUND PIPING, VALVES, FITTINGS, DIMENSIONS, ETC. ARE SHOWN FOR REFERENCE ONLY. REFER TO CIVIL DRAWINGS FOR EXACT LOCATIONS, TYPES, AND SIZES OF ALL COMPONENTS IN ADDITION TO DETAILS OF CONSTRUCTION.

SEE SHEET FP2 FOR NOTES, DETAILS, AND SPECIFICATION


ALL ARM-OVERS TO NEW SPRINKLERS ARE 1" DIAMETER

- FIRE SPRINKLER DEMOLITION NOTES**
- FIRE SPRINKLER CONTRACTOR'S SCOPE OF WORK SHALL INCLUDE:
 - SHUT DOWN AND DRAINING OF EXISTING SYSTEM.
 - DISCONNECTION AND DEMOLITION OF ALL SPRINKLERS THROUGHOUT THE PROPOSED DOLLAR TREE SPACE.
 - DEMOLITION OF EXISTING PIPING, HANGERS, ETC. WHERE INDICATED ON THE PLANS.
 - FIRE SPRINKLER CONTRACTOR SHALL BE RESPONSIBLE FOR REPLACING ANY EXISTING PIPE OR FITTINGS TO REMAIN THAT ARE DAMAGED AS A RESULT OF THEIR WORK AT NO COST TO THE OWNER.

date	project	designed	drawn	checked	mark	date	by	description
06/15/2022	2022/7/1/20216	JW	JW	JW				

Dean Associates
Architects Incorporated
Architecture & Interior Design
7 Kimball Lane Suite E6
Lyndfield MA 01940
p: 781.397.8092 f: 781.397.8094
www.deanassociates.com

ENGINEER OF RECORD:
JAMES L. KIBULOH, PE
LICENSE NO. 103971
JAMES L. KIBULOH, P.E.
PROFESSIONAL ENGINEER, P.C.
210 WEST 47TH ST., 11TH FLOOR
NEW YORK, NY 10018
PHONE: 212-214-8998
CORPORATE CERTIFICATE OF AUTHORITY
#0-41603
WARNING: IT IS A VIOLATION OF THE NEW YORK STATE EDUCATION LAW, ARTICLE 141B, SECTION 2709 FOR ANY PERSON, UNLESS ACTING UNDER THE DIRECTION OF A LICENSED PROFESSIONAL ENGINEER, TO ALTER THIS DOCUMENT IN ANY WAY.

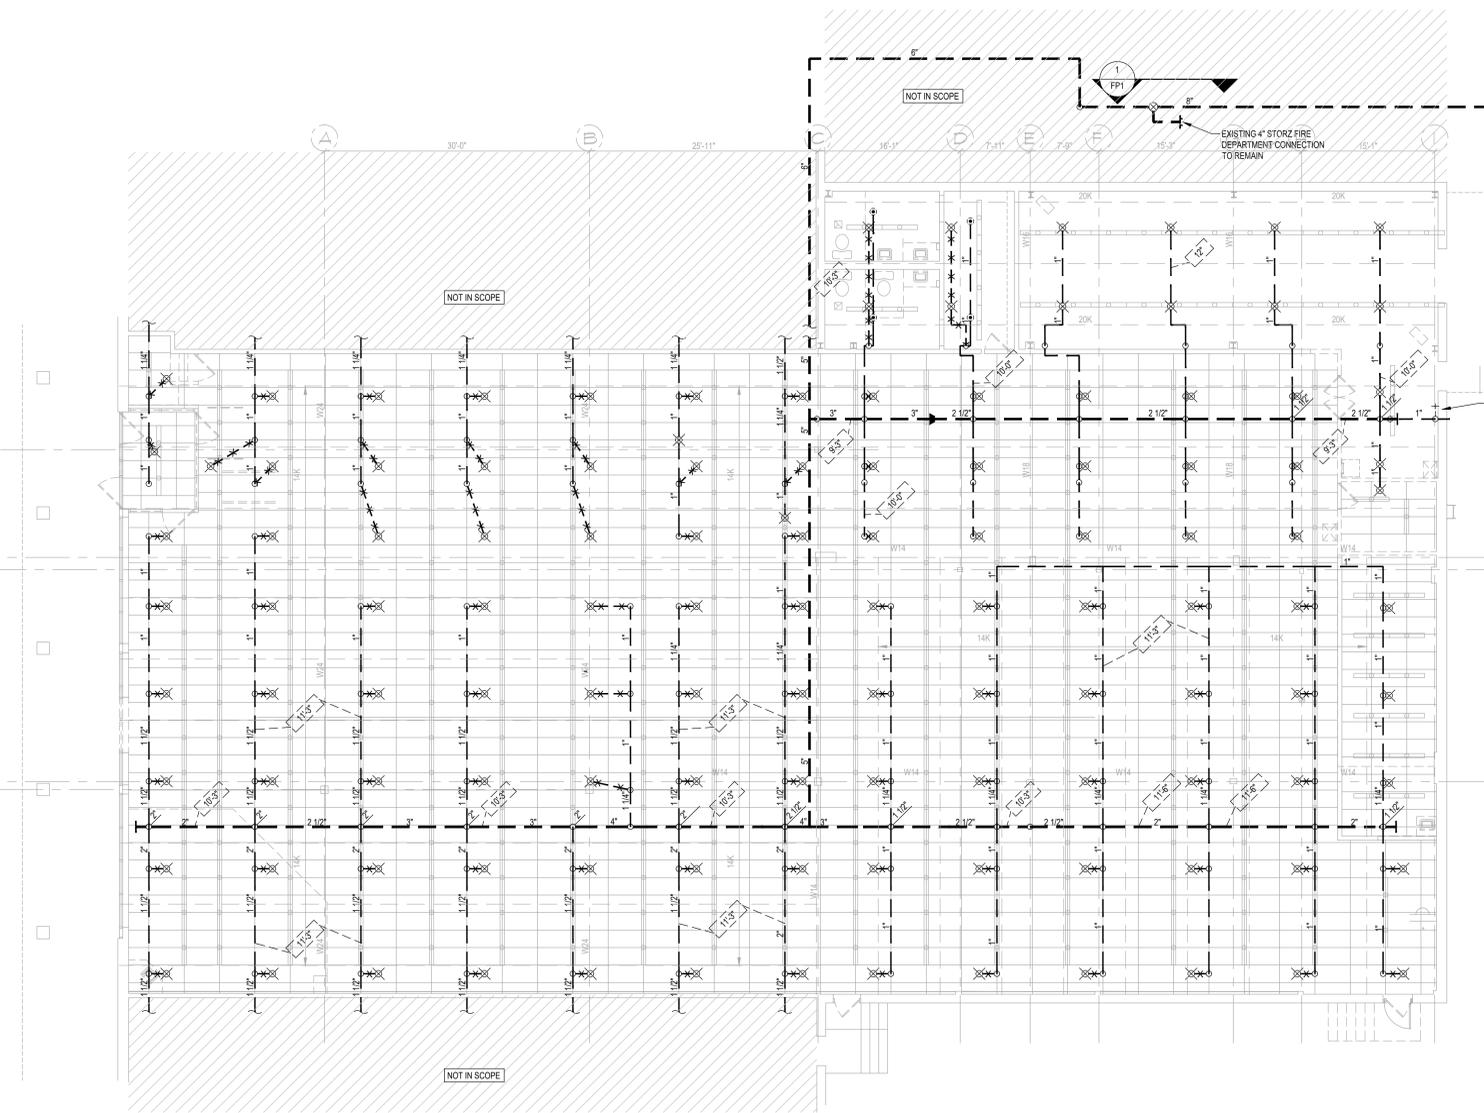

FIRE SPRINKLER PLAN - DEMOLITION WORK
SCALE: 1/8" = 1'-0"
FIN. FLOOR ELEV. = 100'-0"

DOLLAR TREE
166 S. LIBERTY DRIVE - DEAL #13216 / STORE #2573
STONY POINT, NY 10980
FIRE SPRINKLER PLAN - DEMOLITION WORK