

777 Old Saw Mill River Road
Tarrytown, NY 10591-6707
T: 914.847.7400
F: 914.847.7991
www.regeneron.com

Building #17
Campus Expansion Child
Day-care Center

777 Old Saw Mill River Road
Mount Pleasant, NY 10591

Project No. B17-DAYCARE

Architect
GenSLer
1700 Broadway, Suite 400
New York, NY 10019
(212) 492-1400 Phone
(212) 492-1472 Fax


Structural Engineer
Thornton Tomasetti
120 Broadway, 15th Floor
New York, NY 10021
(917) 661-7800 Phone
(917) 661-7801 Fax

MEP / IT / Security Engineer
Cosentini Associates
498 Seventh Avenue
New York, NY 10018
(212) 615-3800 Phone
(212) 615-3700 Fax

Civil Engineer
JMC
120 Bedford Road
Armonk, NY 10504
(914) 273-5225 Phone
(914) 273-2102 Fax

Landscape Architect
Langan
21 Penn Plaza, 360 West 31st Street, 8th Floor
New York, NY 10001
(212) 479-5400 Phone
(212) 479-5444 Fax

Key Plan

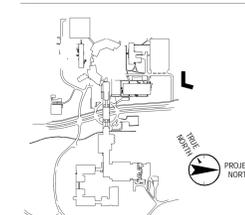

No.	Date	Description
0	06.20.2022	ISSUED FOR PERMIT
1	06.20.2022	100% CONSTRUCTION DOCUMENTS
2	07.01.2022	100% CONSTRUCTION DOCUMENTS-1

Plot Date: 07.01.2022


ALL DRAWINGS AND WRITTEN MATERIALS REPRESENTED ON THIS SHEET CONSTITUTE THE OFFICIAL RECORD FOR THE USE OF THE PROJECT BY REGENERON PHARMACEUTICALS. THESE SHEETS MAY NOT BE REPRODUCED OR COPIED IN WHOLE OR IN PART, NOR MAY ANY OF THE DRAWINGS BE REPRODUCED OR COPIED IN WHOLE OR IN PART, WITHOUT THE WRITTEN CONSENT OF REGENERON PHARMACEUTICALS. REGENERON PHARMACEUTICALS SHALL BE RESPONSIBLE FOR THE QUALITY OF ANY WORK PERFORMED BY ANY OTHER PARTY. REGENERON PHARMACEUTICALS SHALL BE RESPONSIBLE FOR THE QUALITY OF ANY WORK PERFORMED BY ANY OTHER PARTY. REGENERON PHARMACEUTICALS SHALL BE RESPONSIBLE FOR THE QUALITY OF ANY WORK PERFORMED BY ANY OTHER PARTY.

Professional Seal and Signature

Vendor Name: COSENTINI
Vendor Project No.: 210104
Discipline: Electrical Drawn By: AI
ELECTRICAL SITE LIGHTING PLAN

Scale: 1/16" = 1'-0" Floor:

E-052

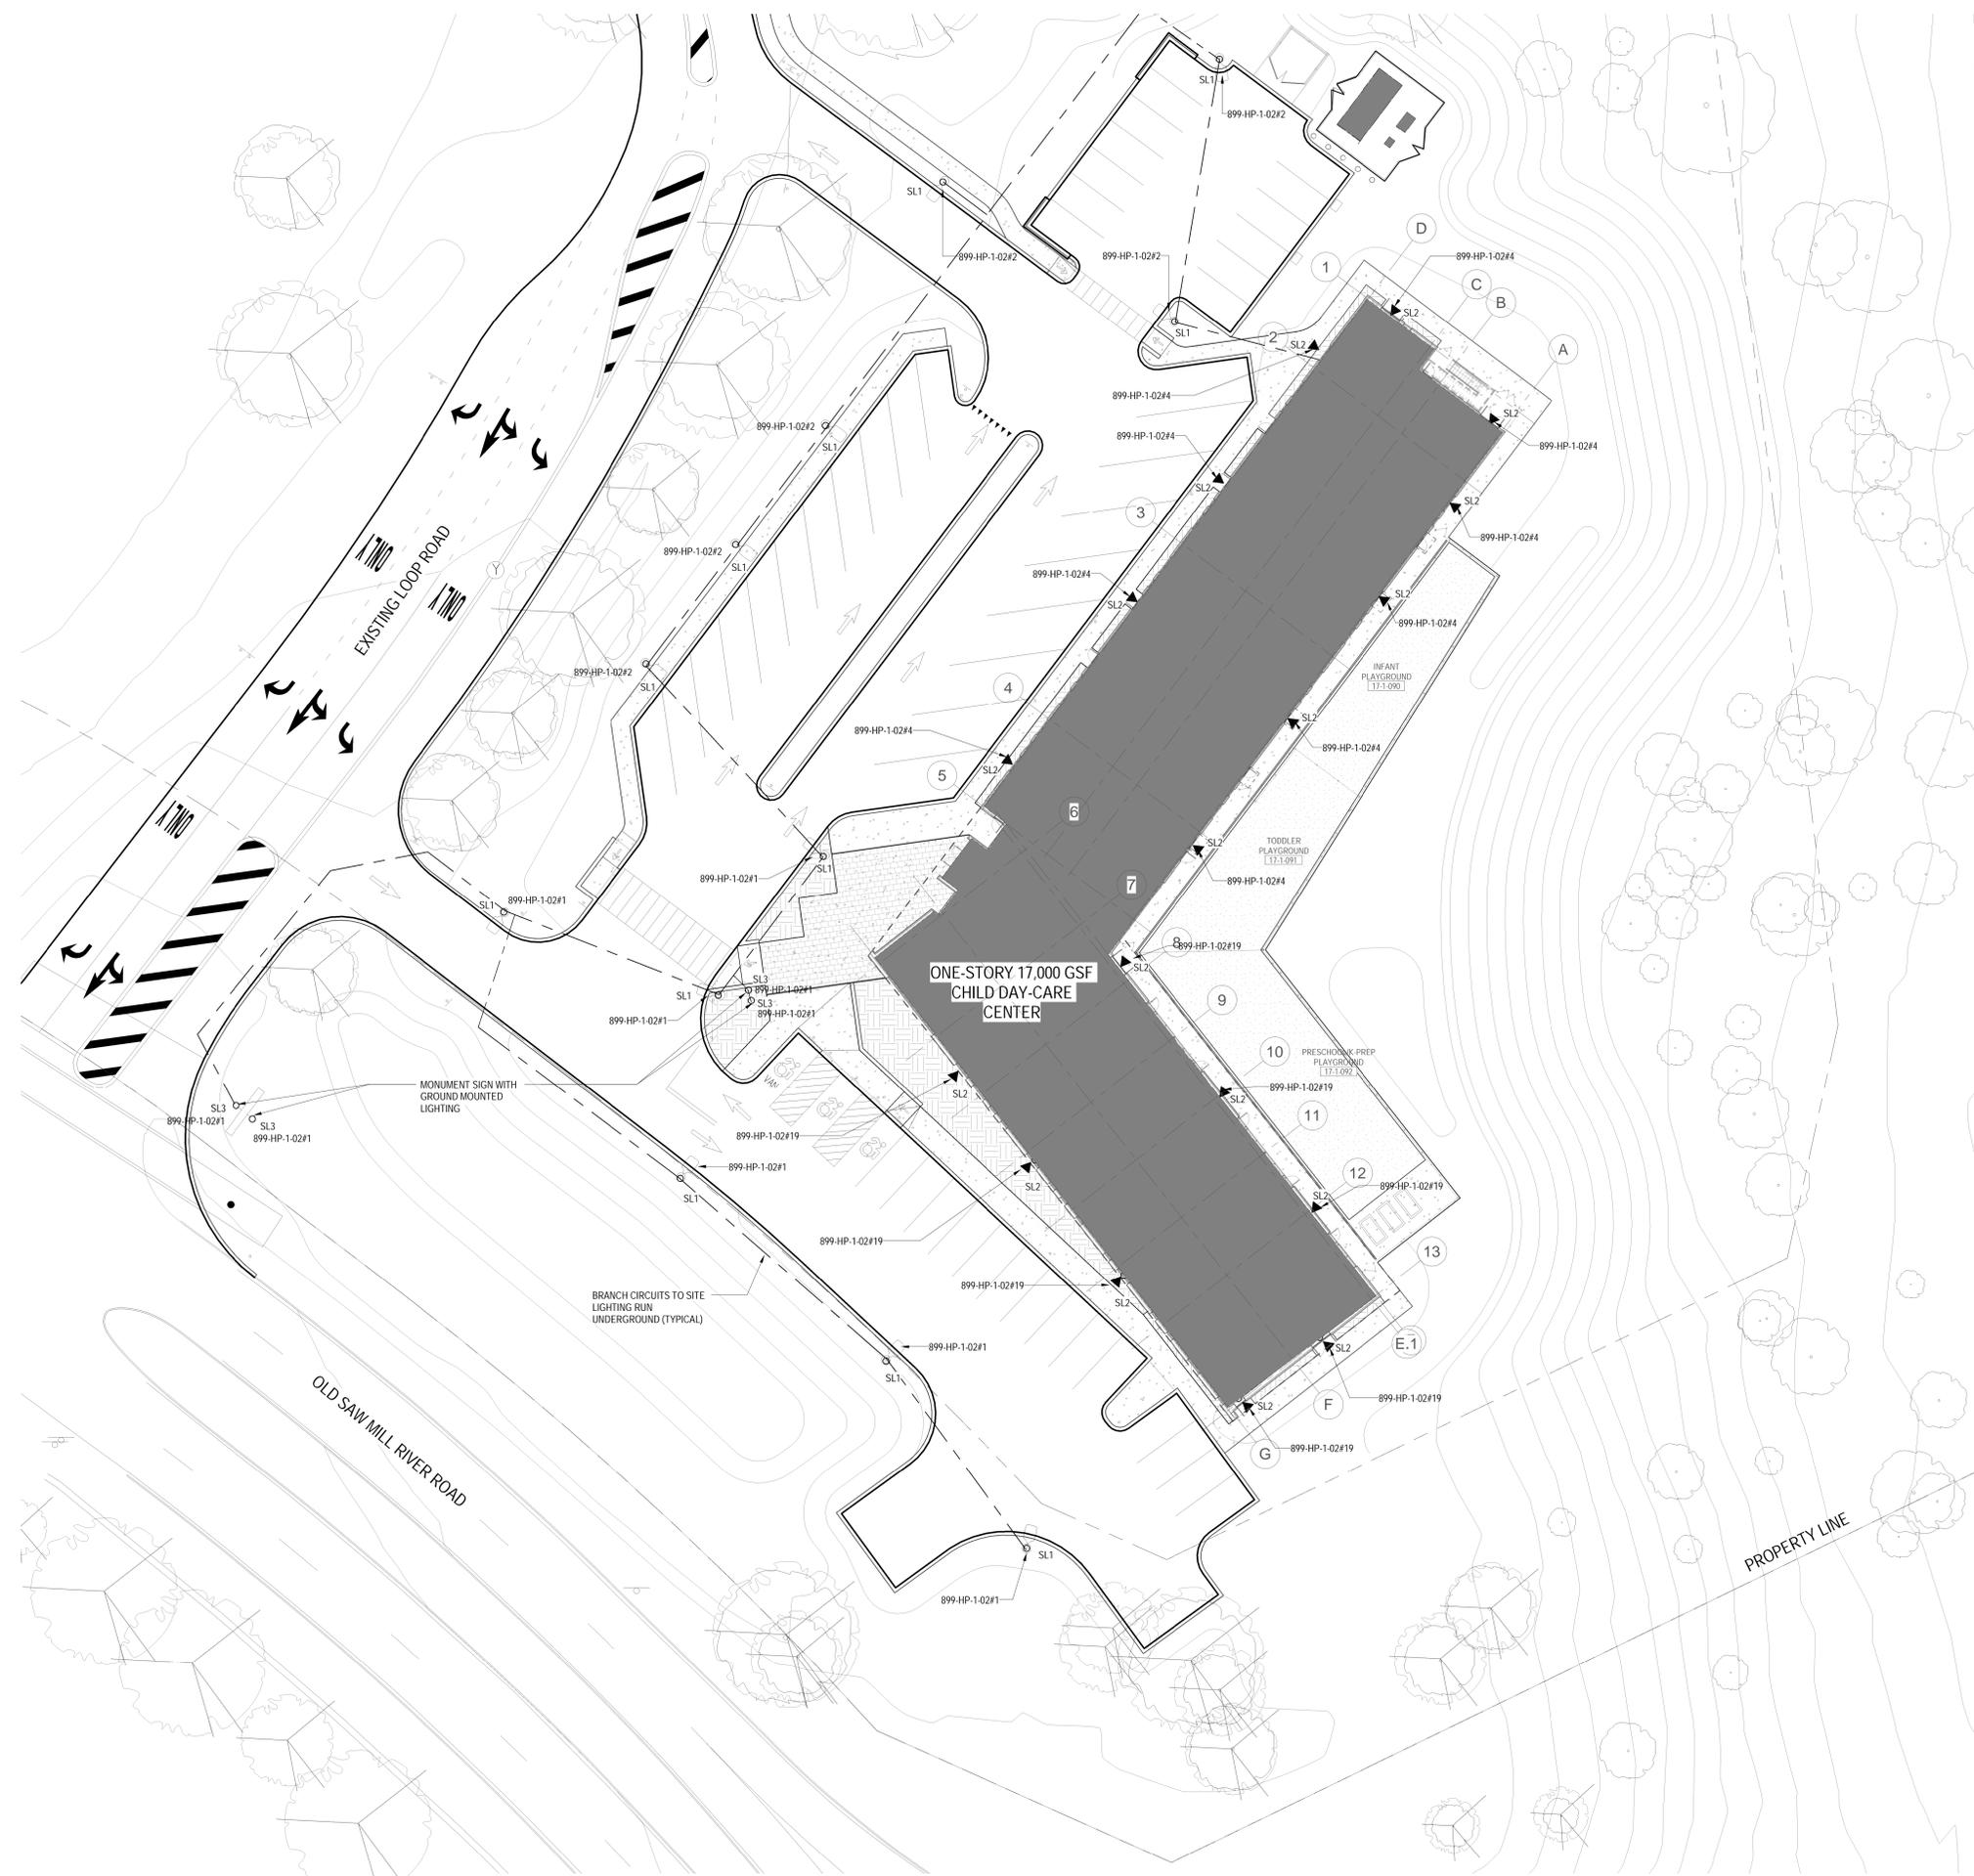

- NOTES:
- ALL UNDERGROUND CONDUITS SHALL BE RIGID GALVANIZED CONDUIT PVC COATED WITH THREADED FITTINGS, UNLESS SPECIFIED ELSEWHERE.
 - ALL UNDERGROUND CONDUITS TO BE INSTALLED 24" BELOW GRADE. REFER TO DETAIL ON DRAWING E-502.
 - BRANCH CIRCUITS TO SITE LIGHTING SHALL BE # 8 WIRE, INSTALL GROUNDWIRE IN ALL UNDERGROUND CONDUIT.
 - ALL SITE LIGHTING SHALL BE CONTROLLED VIA PHOTO-CELL TIME CLOCK VIA THE LIGHTING CONTROL PANEL. FINAL LOCATION OF THE EXTERIOR PHOTOCELL TO BE DETERMINED IN THE FIELD.
 - FOR SITE LIGHTING FIXTURE SCHEDULE REFER TO DRAWING E-603.
 - FOR EXACT QUANTITY, LOCATION, AND TYPE FOR SITE LIGHTING FIXTURES, REFER TO CIVIL ENGINEERS DRAWING C-600 FOR ADDITIONAL INFORMATION.
 - COORDINATE EXCAVATION AND BACKFILL FOR UNDERGROUND EXTERIOR CONDUIT WITH GENERAL CONTRACTOR.
 - FOR LIGHTING CONTROL ZONE SCHEDULES REFER TO DRAWING E-602.

TO THE BEST OF MY KNOWLEDGE, BELIEF AND PROFESSIONAL JUDGMENT, THESE PLANS AND SPECIFICATIONS ARE IN COMPLIANCE WITH THE 2020 ENERGY CONSERVATION CODE OF NYS

This plan is approved only for work indicated on the application specification sheet. All other matters shown are not to be relied upon, or to be considered as either being approved or in accordance with applicable codes.

Alterations or additions to this engineering document by an unlicensed person is a violation of Chapter 16, Title VIII, Article 145 § 7209.2 of the New York State Education Law.

FILE: B:\300-3000-3000-000 - Regeneron Day Care Facility - Tarrytown\210104_TTCO_Daycare_E-052\REV_PLOTTED_ON_112321

1 SITE LIGHTING PLAN
1/16" = 1'-0"

© 11/23/21 REGENERON PHARMACEUTICALS, INC.