





- ### CEILING REMOVAL LEGEND

- | | |
|---|--|
|  | 4'x8" SURFACE MOUNTED LIGHT
FIXTURE TO BE REMOVED. |
|  | 10'x12" 1/2" SURFACE MOUNTED
LIGHT FIXTURE TO BE REMOVED. |
|  | 46'x46" SURFACE MOUNTED LIGHT
FIXTURE TO BE REMOVED. |
|  | 24"x24" RECESSED OR SURFACE
MOUNTED LIGHT FIXTURE TO
BE REMOVED. |
|  | 12"x12" RECESSED LIGHT FIXTURE
TO BE REMOVED. |
|  | RECESSED CAN LIGHT FIXTURE TO
BE REMOVED. |
|  | CEILING MOUNTED RECESSED
SPRINKLER TO BE REMOVED. |
|  | FIRE ALARM SMOKE DETECTOR TO
BE REMOVED. |
|  | MOTION SENSOR TO BE REMOVED. |
|  | SURVEILLANCE CAMERA BUBBLE
TO BE REMOVED. |
|  | FIRE STROBE TO BE REMOVED. |
|  | FACE PLATE TO BE REMOVED. |
|  | CEILING MOUNTED EXIT SIGN TO
BE REMOVED. |
|  | EXIT SIGN, MOUNTED ABOVE DOOR,
TO BE REMOVED. |
|  | EXISTING CANTILEVER HANGER TO
REMAIN. |
|  | EXISTING 12"x12" CONCEALED SPRINKLER
SYSTEM TO REMAIN. |
|  | EXISTING 12"x24" CEILING PANEL
TO REMAIN. |
|  | EXISTING 6"x6" GRID CEILING SYSTEM
TO REMAIN. |
|  | NOTE: EXISTING DEVICES WITHIN
REMOVED CEILING AREAS SHALL BE
REMOVED AND REINSTALLED. SEE
ELECTRICAL DRAWINGS FOR
RELOCATION OF NEW DEVICES AND
RE-INSTALLATION OF DEVICES. |



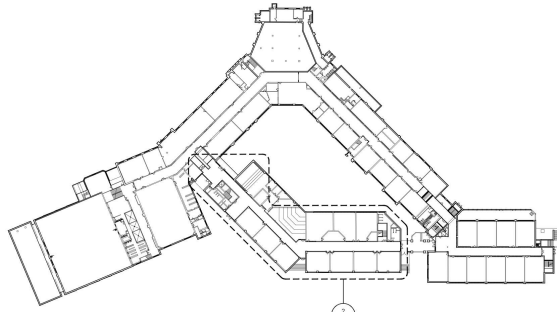

KEY PLAN OF SITE
SCALE: 1/8" = 1'-0"

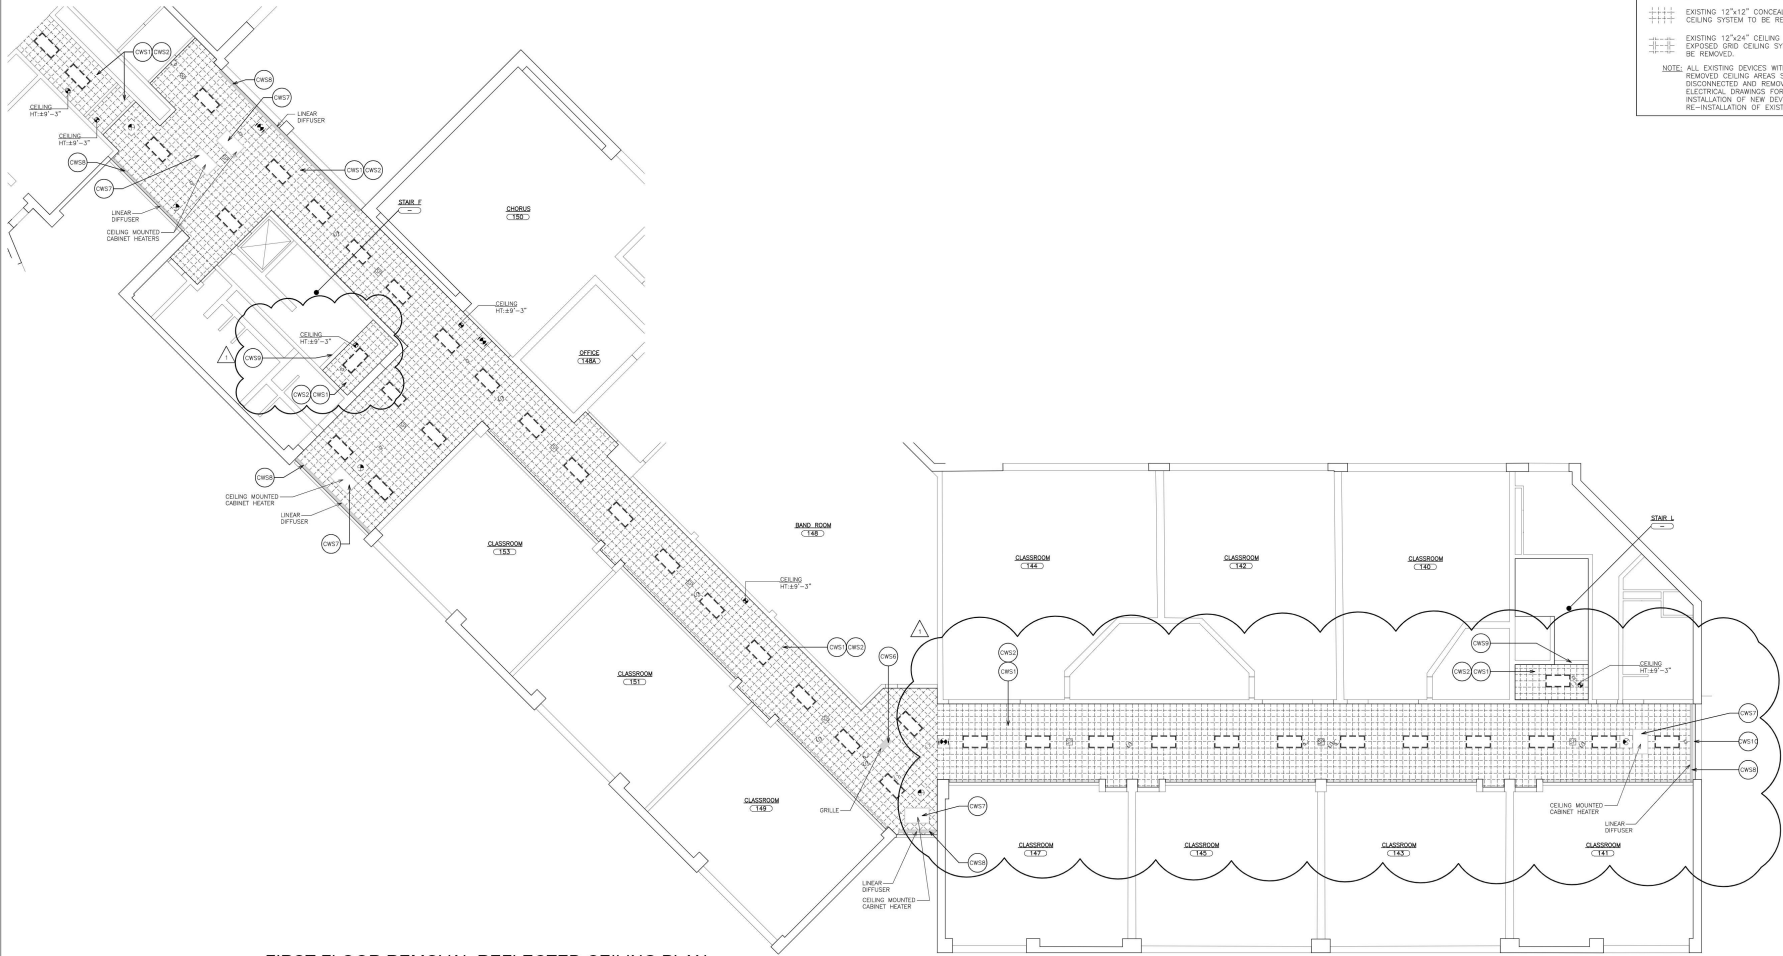

2 FIRST FLOOR REMOVAL REFLECTED CEILING PLAN
SCALE: 1/8" = 1'-0"

CEILING WORKSCOPE NOTES:

- (RWS) REMOVE EXISTING SUSPENDED CEILING IN ITS ENTIRETY, INCLUDING ALL GRID, BLACK IRON SUPPORT FRAMING, SUPPLEMENTAL FRAMING AND PERIMETER TRIM. DISCONNECT AND REMOVE ALL ELECTRICAL DEVICES. SEE ELECTRICAL DRAWINGS FOR ADDITIONAL INFORMATION. TEMPORARILY SUPPORT ALL LOOSE AND HANGING WIRES OR PIPING.
- (RWS) AFTER REMOVAL OF CEILING SYSTEM AND PERIMETER TRIM, PREPARE AND PAINT EXISTING WALL SURFACE IN AN AREA 9" WIDE, IMMEDIATELY ABOVE AND BELOW THE EXISTING CEILING LINE PRIOR TO INSTALLATION OF NEW PERIMETER TRIM. MATCH EXISTING ADJACENT WALL COLOR AND FINISH. SEE SPECIFICATION SECTION 09 9000.
- (RWS) REMOVE EXISTING EXPOSED ELECTRICAL CONDUIT. INSTALL NEW CONDUIT ABOVE NEW SUSPENDED CEILING SYSTEM. SEE ELECTRICAL DRAWINGS FOR REMOVAL AND RE-INSTALLATION REQUIREMENTS. PATCH AND REPAIR OPENINGS IN EXISTING SOFFIT AT CONDUIT PENETRATIONS.
- (RWS) TEMPORARILY BRACE TOP OF EXISTING PARTITION PRIOR TO REMOVAL OF EXISTING CEILING GRID. INSTALL NEW METAL STUD FRAMING AND DIAGONAL BRACING IN ACCORDANCE WITH DETAIL 13/A-650.
- (RWS) EXISTING SUSPENDED CEILING SYSTEM TO REMAIN. CUT EXISTING GRID AND SUPPLEMENTAL FRAMING MEMBERS ALONG TOP OF EXISTING PARTITION. PROVIDE ADDITIONAL WIRE HANGERS TO SUPPORT CUT END OF SUPPLEMENTAL FRAMING AND GRID TO REMAIN.
- (RWS) EXISTING AIR OUTLETS TO REMAIN. MODIFY GRID TO FRAME AROUND EXISTING DUCT. EXISTING AIR DIFFUSER/GRILLE TO BE REMOVED. CLEANED, PREPARED AND PAINTED IN ACCORDANCE WITH SPECIFICATION SECTION 09 9000.
- (RWS) EXISTING CEILING MOUNTED CABINET HEATER TO REMAIN. CLEAN, PREPARE AND PAINT EXPOSED SURFACES IN ACCORDANCE WITH SPECIFICATION SECTION 09 9000. PROVIDE NEW PERIMETER TRIM AND INSTALL NEW CEILING AROUND EXISTING CABINET.
- (RWS) EXISTING LINEAR DIFFUSER TO REMAIN. MODIFY CEILING GRID TO FRAME AROUND EXISTING DUCT. REMOVE AND CLEAN EXISTING DIFFUSER. PROVIDE NEW PERIMETER TRIM, IF REQUIRED, AND REINSTALL AFTER NEW CEILING INSTALLATION.
- (RWS) EXISTING PLASTER SOFFIT TO REMAIN. REMOVE ANY LOOSE OR FLAKING PLASTER. FILL ANY OPEN HOLES. PREPARE AND PAINT ENTIRE AREA IN ACCORDANCE WITH SPECIFICATION SECTION 09 9000.
- (RWS) REMOVE EXISTING MASONRY CLOSURE BOARD. PROVIDE NEW 0.040 FINISHED ALUMINUM CLOSURE TRIM BETWEEN EXISTING LINEAR DIFFUSER AND DOOR FRAME FRAME.

CEILING REMOVAL LEGEND

- 4"x48" SURFACE MOUNTED LIGHT FIXTURE TO BE REMOVED.
 - - - 10"/12"/14"x48" SURFACE MOUNTED LIGHT FIXTURE TO BE REMOVED.
 - - - 24"x48" RECESSED LIGHT FIXTURE TO BE REMOVED.
 - - - 46"x46" SURFACE MOUNTED LIGHT FIXTURE TO BE REMOVED.
 - - - 24"x24" RECESSED OR SURFACE MOUNTED LIGHT FIXTURE TO BE REMOVED.
 - - - 12"x12" RECESSED LIGHT FIXTURE TO BE REMOVED.
 - - - RECESSED CAN LIGHT FIXTURE TO BE REMOVED.
 - - - CEILING MOUNTED RECESSED SPREADER TO BE REMOVED.
 - - - FIRE ALARM SMOKE DETECTOR TO BE REMOVED.
 - - - MOTION SENSOR TO BE REMOVED.
 - - - SURVEILLANCE CAMERA BUBBLE TO BE REMOVED.
 - - - FIRE STROBE TO BE REMOVED.
 - - - FACE PLATE TO BE REMOVED.
 - - - CEILING MOUNTED EXIT SIGN TO BE REMOVED.
 - - - CEILING MOUNTED EXIT SIGN W/ DIRECTIONAL ARROW TO BE REMOVED.
 - - - EXISTING ACCESS PANEL TO BE REMOVED.
 - - - EXISTING CABINET HEATER TO REMAIN.
 - - - EXISTING LINEAR DIFFUSER TO REMAIN.
 - - - EXISTING 12"x12" CONCEALED SPLINE CEILING SYSTEM TO BE REMOVED.
 - - - EXISTING 12"x24" CEILING PANEL, EXPOSED GRID CEILING SYSTEM TO BE REMOVED.
- NOTE: ALL EXISTING DEVICES WITHIN REMOVED CEILING AREAS SHALL BE DISCONNECTED AND REMOVED. SEE ELECTRICAL DRAWINGS FOR INSTALLATION OF NEW DEVICES AND RE-INSTALLATION OF EXISTING.




Fuller & Angelo P.C.
Architects Planners
445 Westchester Road
Roseland, New York 10962
TEL: 914.486.4444
FAX: 914.486.4444
WWW.FULLER-ANGELO.COM
Project 0311 Roosevelt High School
Fuller & Angelo P.C.

CONSTRUCTION




YONKERS PUBLIC SCHOOLS
ROOSEVELT HIGH SCHOOL
REPLACEMENT OF CEILINGS AND LIGHTS PHASE II
0311 (Lobbyroom Room, YONKERS N.Y. 10710)
2.9.2022

EAR PROJECT NO.	Y1800004
YPS NO.	10891
ADDENDUM 1	3.4.2022
REVISION	DATE BY
ISSUED FOR BID	JAN
DRAWN BY	JE
CHECKED BY	JE
SHEET SIZE	MIN 9" W x 4"
SCALE	AS NOTED
SHEET TITLE	ROOSEVELT HS FIRST FLOOR REMOVALS REFLECTED CEILING PLAN
SHEET NO.	AR-201

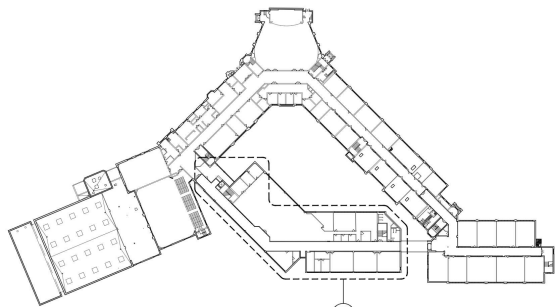

KEY PLAN OF SITE
SCALE: 1/8" = 1'-0"

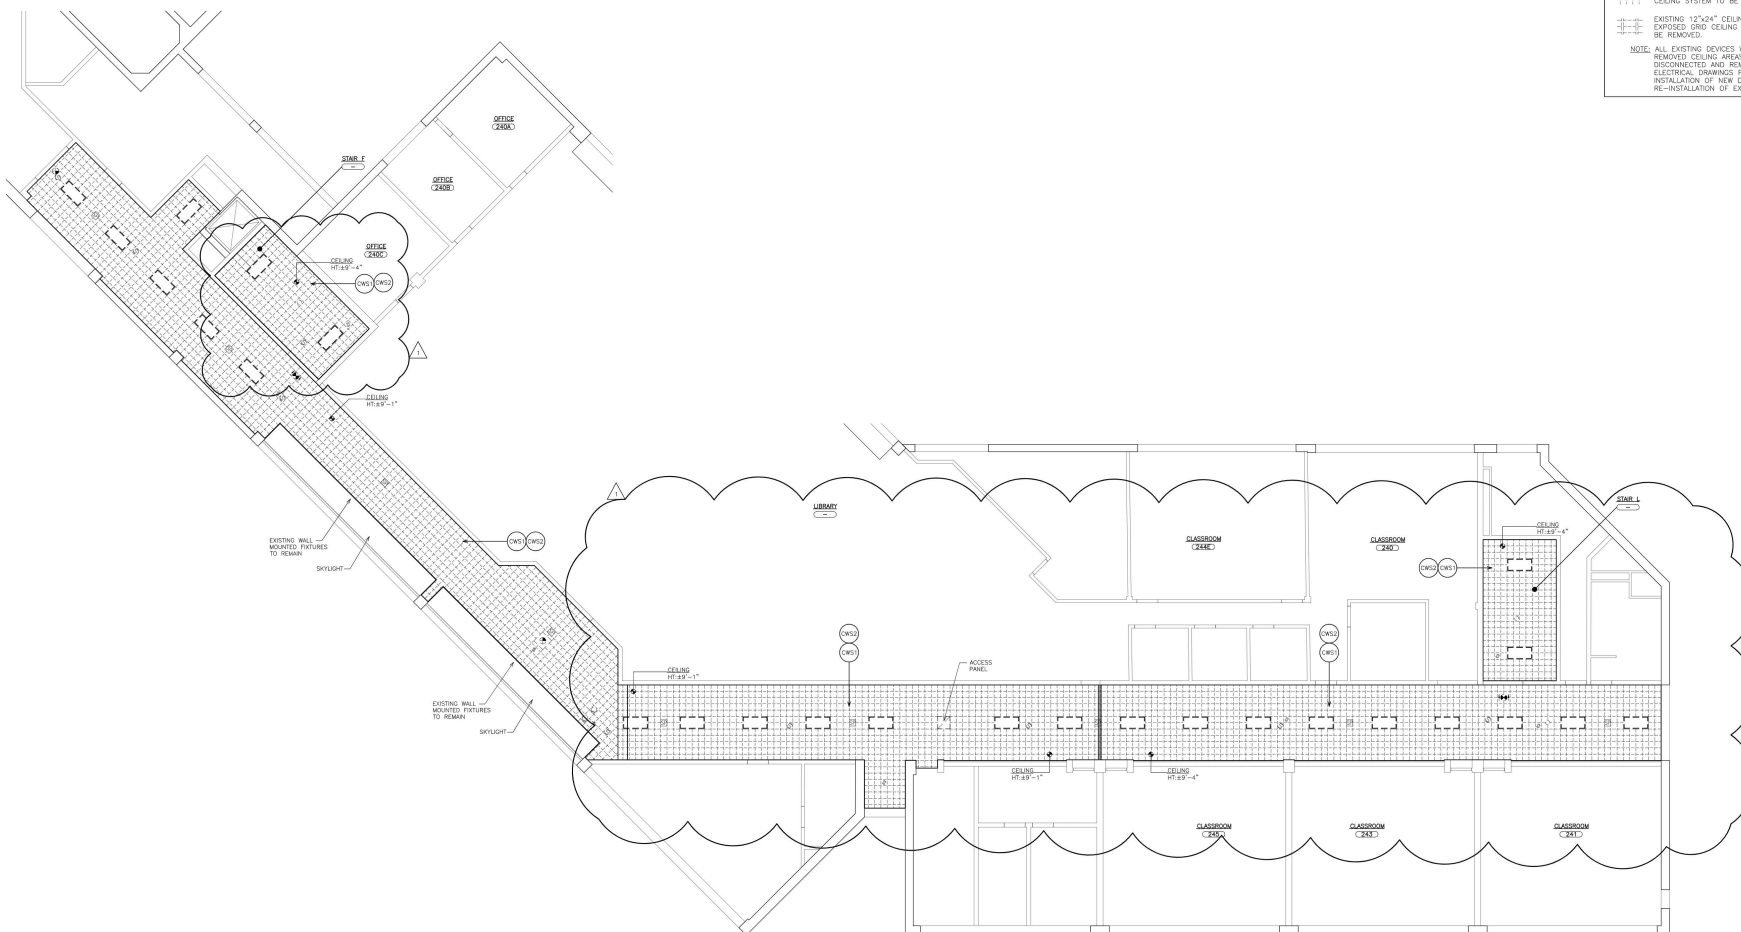

2 SECOND FLOOR REMOVAL REFLECTED CEILING PLAN
SCALE: 1/8" = 1'-0"

CEILING WORKSCOPE NOTES:

- (CWS) REMOVE EXISTING SUSPENDED CEILING IN ITS ENTIRETY, INCLUDING ALL GRID, BLACK IRON SUPPORT FRAMING, SUPPLEMENTAL FRAMING AND PERIMETER TRIM. DISCONNECT AND REMOVE ALL ELECTRICAL DEVICES. SEE ELECTRICAL DRAWINGS FOR ADDITIONAL INFORMATION. TEMPORARILY SUPPORT ALL LOOSE AND HANGING WIRES OR PIPING.
- (CWS) AFTER REMOVAL OF CEILING SYSTEM AND PERIMETER TRIM, PREPARE AND PAINT EXISTING WALL SURFACE IN AN AREA 9" WIDE, IMMEDIATELY ABOVE AND BELOW THE EXISTING CEILING LINE PRIOR TO INSTALLATION OF NEW PERIMETER TRIM. MATCH EXISTING ADJACENT WALL COLOR AND FINISH. SEE SPECIFICATION SECTION 09 9000.
- (CWS) REMOVE EXISTING EXPOSED ELECTRICAL CONDUIT. INSTALL NEW CONDUIT ABOVE NEW SUSPENDED CEILING SYSTEM. SEE ELECTRICAL DRAWINGS FOR REMOVAL AND RE-INSTALLATION REQUIREMENTS. PATCH AND REPAIR OPENINGS IN EXISTING SOFFIT AT CONDUIT PENETRATIONS.
- (CWS) TEMPORARILY BRACE TOP OF EXISTING PARTITION PRIOR TO REMOVAL OF EXISTING CEILING GRID. INSTALL NEW METAL STUD FRAMING AND DIAGONAL BRACING IN ACCORDANCE WITH DETAIL 13/A-650.
- (CWS) EXISTING SUSPENDED CEILING SYSTEM TO REMAIN. CUT EXISTING GRID AND SUPPLEMENTAL FRAMING MEMBERS ALONG TOP OF EXISTING PARTITION. PROVIDE ADDITIONAL WIRE HANGERS TO SUPPORT CUT END OF SUPPLEMENTAL FRAMING AND GRID TO REMAIN.
- (CWS) EXISTING AIR OUTLETS TO REMAIN. MODIFY GRID TO FRAME AROUND EXISTING DUCT. EXISTING AIR DIFFUSERS/GRILLE TO BE REMOVED. CLEANED, PREPARED AND PAINTED IN ACCORDANCE WITH SPECIFICATION SECTION 09 9000.
- (CWS) EXISTING CEILING MOUNTED CABINET HEATER TO REMAIN. CLEAN, PREPARE AND PAINT EXPOSED SURFACES IN ACCORDANCE WITH SPECIFICATION SECTION 09 9000. PROVIDE NEW PERIMETER TRIM AND INSTALL NEW CEILING AROUND EXISTING CABINET.
- (CWS) EXISTING LINEAR DIFFUSERS TO REMAIN. MODIFY CEILING GRID TO FRAME AROUND EXISTING DUCT. REMOVE AND CLEAN EXISTING DIFFUSERS. PROVIDE NEW PERIMETER TRIM, IF REQUIRED, AND REINSTALL AFTER NEW CEILING INSTALLATION.
- (CWS) EXISTING PLASTER SOFFIT TO REMAIN. REMOVE ANY LOOSE OR FLAKING PLASTER. FILL ANY OPEN HOLES. PREPARE AND PAINT ENTIRE AREA IN ACCORDANCE WITH SPECIFICATION SECTION 09 9000.
- (CWS) REMOVE EXISTING MAINTENANCE CLOSURE DOORS. PROVIDE NEW 0.040 FINISHED ALUMINUM CLOSURE TRIM BETWEEN EXISTING LINEAR DIFFUSER AND DOOR TRANSOM FRAME.

CEILING REMOVAL LEGEND

- 4"x48" SURFACE MOUNTED LIGHT FIXTURE TO BE REMOVED.
 - - - 10"x12"/14"x48" SURFACE MOUNTED LIGHT FIXTURE TO BE REMOVED.
 - - - 24"x48" RECESSED LIGHT FIXTURE TO BE REMOVED.
 - - - 46"x46" SURFACE MOUNTED LIGHT FIXTURE TO BE REMOVED.
 - - - 24"x24" RECESSED OR SURFACE MOUNTED LIGHT FIXTURE TO BE REMOVED.
 - - - 12"x12" RECESSED LIGHT FIXTURE TO BE REMOVED.
 - - - RECESSED CAN LIGHT FIXTURE TO BE REMOVED.
 - - - CEILING MOUNTED RECESSED SPEAKER TO BE REMOVED.
 - - - FIRE ALARM SMOKE DETECTOR TO BE REMOVED.
 - - - MOTION SENSOR TO BE REMOVED.
 - - - SURVEILLANCE CAMERA BUBBLE TO BE REMOVED.
 - - - FIRE STROBE TO BE REMOVED.
 - - - FACE PLATE TO BE REMOVED.
 - - - CEILING MOUNTED EXIT SIGN TO BE REMOVED.
 - - - CEILING MOUNTED EXIT SIGN W/ DIRECTIONAL ARROW TO BE REMOVED.
 - - - EXISTING ACCESS PANEL TO BE REMOVED.
 - - - EXISTING CABINET HEATER TO REMAIN.
 - - - EXISTING LINEAR DIFFUSER TO REMAIN.
 - - - EXISTING 12"x12" CONCEALED SPLINE CEILING SYSTEM TO BE REMOVED.
 - - - EXISTING 12"x24" CEILING PANEL, EXPOSED GRID CEILING SYSTEM TO BE REMOVED.
- NOTE: ALL EXISTING DEVICES WITHIN REMOVED CEILING AREAS SHALL BE DISCONNECTED AND REMOVED. SEE ELECTRICAL DRAWINGS FOR INSTALLATION OF NEW DEVICES AND RE-INSTALLATION OF EXISTING.

OWNER
YONKERS PUBLIC SCHOOLS
ROOSEVELT HIGH SCHOOL
REPLACEMENT OF CEILINGS AND LIGHTS PHASE II
0.31 LUDLOW ROAD, YONKERS, N.Y. 10710
TEL: 914.936.4444
WWW.YONKERSPUBLICSCHOOLS.EDU

ARCHITECTS
FULLER & D'ANGELO P.C.
ARCHITECTS
PLANNERS
400 WALL STREET, SUITE 2000
NEW YORK, N.Y. 10038
TEL: 212.405.1111
WWW.FULLERANDANGELO.COM
DESIGNED BY: FULLER & D'ANGELO
DRAWN BY: FULLER & D'ANGELO

DATE: 3.4.2022
REVISION: DATE BY
ISSUED FOR BID: JAU
DRAWN BY: JAU
CHECKED BY: JAU
SHEET NO: 1001
SCALE: AS NOTED

SHEET TITLE
ROOSEVELT HS
SECOND FLOOR
REMOVALS REFLECTED
CEILING PLAN


PROJECT NO. 1001
SHEET NO. 1001

AR-202



- ## CEILING LEGEND
- | | |
|---|---|
|  | 2'x4"x48" RECESSED LIGHT FIXTURE. |
|  | 2'x4"x24" RECESSED LIGHT FIXTURE. |
|  | DYPHISM BOARD CEILING OR SOFFIT |
|  | CEILING MOUNTED RECESSED
SPEAKER |
|  | FIRE ALARM SMOKE DETECTOR |
|  | MOTION SENSOR |
|  | SURVEILLANCE CAMERA BUBBLE |
|  | FIRE STROBE |
|  | FACE PLATE |
|  | CEILING MOUNTED EXIT SIGN |
|  | CEILING MOUNTED EXIT SIGN W/
DIRECTIONAL ARROW |
|  | ACCESS PANEL |
|  | UNIT VENTILATOR |
|  | GRILLE |
|  | 2'x4"x24" CEILING PANELS |
|  | 2'x4"x48" CEILING PANELS |
|  | CEILING GRID STARTING POINT |
- NOTES:
1. NOT ALL SYMBOLS ARE NECESSARILY USED
ON THIS PROJECT.
2. REFER TO MECHANICAL AND ELECTRICAL
DRAWINGS FOR ADDITIONAL INFORMATION.




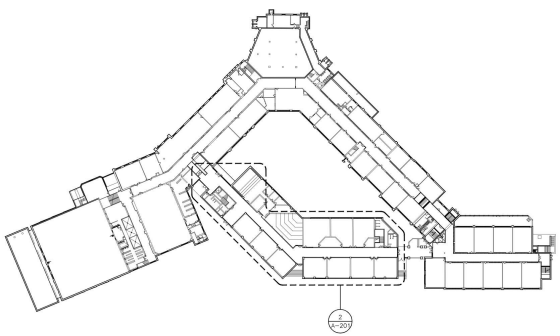

KEY PLAN OF SITE
SCALE: 1/8" = 1'-0"



2 FIRST FLOOR REFLECTED CEILING PLAN
SCALE: 1/8" = 1'-0"

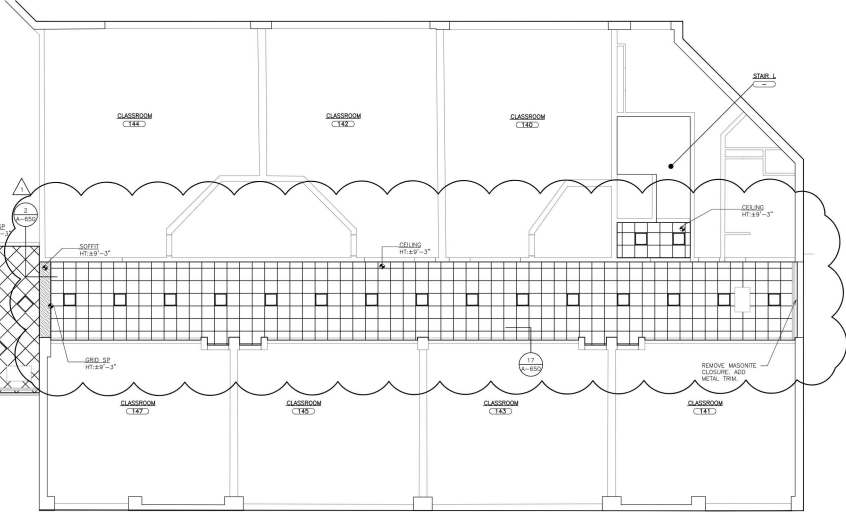

- CEILING WORKSCOPE NOTES:**
- (WS) REMOVE EXISTING SUSPENDED CEILING IN ITS ENTIRETY, INCLUDING ALL GRID, BLACK IRON SUPPORT FRAMING, SUPPLEMENTAL FRAMING AND PERIMETER TRIM. DISCONNECT AND REMOVE ALL ELECTRICAL DEVICES. SEE ELECTRICAL DRAWINGS FOR ADDITIONAL INFORMATION. TEMPORARILY SUPPORT ALL LOOSE AND HANGING WIRES OR PIPING.
 - (WS) AFTER REMOVAL OF CEILING SYSTEM AND PERIMETER TRIM, PREPARE AND PAINT EXISTING WALL SURFACE IN AN AREA 9" WIDE, IMMEDIATELY ABOVE AND BELOW THE EXISTING CEILING LINE PRIOR TO INSTALLATION OF NEW PERIMETER TRIM. MATCH EXISTING ADJACENT WALL COLOR AND FINISH. SEE SPECIFICATION SECTION 09 5000.
 - (WS) REMOVE EXISTING EXPOSED ELECTRICAL CONDUIT. INSTALL NEW CONDUIT ABOVE NEW SUSPENDED CEILING SYSTEM. SEE ELECTRICAL DRAWINGS FOR REMOVAL AND RE-INSTALLATION REQUIREMENTS. PATCH AND REPAIR OPENINGS IN EXISTING SOFFIT AT CONDUIT PENETRATIONS.
 - (WS) TEMPORARILY BRACE TOP OF EXISTING PARTITION PRIOR TO REMOVAL OF EXISTING CEILING GRID. INSTALL NEW METAL STUD FRAMING AND DIAGONAL BRACING IN ACCORDANCE WITH DETAIL 13/A-600.
 - (WS) EXISTING SUSPENDED CEILING SYSTEM TO REMAIN. CUT EXISTING GRID AND SUPPLEMENTAL FRAMING MEMBERS ALONG TOP OF EXISTING PARTITION. PROVIDE ADDITIONAL WIRE HANGERS TO SUPPORT CUT END OF SUPPLEMENTAL FRAMING AND GRID TO REMAIN.
 - (WS) EXISTING AIR OUTLETS TO REMAIN. WOOLY GRID TO FRAME AROUND EXISTING DUCT. EXISTING AIR DIFFUSER/GRILLE TO BE REMOVED, CLEANED, PREPARED AND PAINTED IN ACCORDANCE WITH SPECIFICATION SECTION 09 5000.
 - (WS) EXISTING CEILING MOUNTED HEATER TO REMAIN. CLEAN, PREPARE AND PAINT EXISTING SURFACES IN ACCORDANCE WITH SPECIFICATION SECTION 09 5000. PROVIDE NEW PERIMETER TRIM AND INSTALL NEW CEILING AROUND EXISTING CORNER.
 - (WS) EXISTING LINEAR DIFFUSER TO REMAIN. WOOLY CEILING GRID TO FRAME AROUND EXISTING DUCT. REMOVE AND CLEAN EXISTING DIFFUSER. PROVIDE NEW PERIMETER TRIM, IF REQUIRED, AND REINSTALL AFTER NEW CEILING INSTALLATION.
 - (WS) EXISTING PLASTER SOFFIT TO REMAIN. REMOVE ANY LOOSE OR FLAKING PAINT. FILL ANY OPEN HOLES. PREPARE AND PAINT ENTIRE AREA IN ACCORDANCE WITH SPECIFICATION SECTION 09 5000.
 - (WS) REMOVE EXISTING MAGNETIC CLOSURE BOARD. PROVIDE NEW 0.040 FINISHED ALUMINUM CLOSURE TRIM BETWEEN EXISTING LINEAR DIFFUSER AND DOOR TRANSOM FRAME.

- CEILING LEGEND**
- 24"x48" RECESSED LIGHT FIXTURE.
 - 24"x24" RECESSED LIGHT FIXTURE.
 - GYPSON BOARD CEILING OR SOFFIT
 - CEILING MOUNTED RECESSED SPEAKER
 - FIRE ALARM SMOKE DETECTOR
 - MOTION SENSOR
 - SURVEILLANCE CAMERA BUBBLE
 - FIRE STROBE
 - FACE PLATE
 - CEILING MOUNTED EXIT SIGN
 - CEILING MOUNTED EXIT SIGN W/ DIRECTIONAL ARROW
 - ACCESS PANEL
 - UNIT VENTILATOR
 - GRILLE
 - 24"x24" CEILING PANELS
 - 24"x48" CEILING PANELS
 - CEILING GRID STARTING POINT
- NOTES:
1. NOT ALL SYMBOLS ARE NECESSARILY USED
2. REFER TO MECHANICAL AND ELECTRICAL DRAWINGS FOR ADDITIONAL INFORMATION.

OWNER
YONKERS PUBLIC SCHOOLS
ROOSEVELT HIGH SCHOOL
REPLACEMENT OF CEILINGS AND LIGHTS PHASE II
0.311 YONKERS PUBLIC SCHOOLS, YONKERS, N.Y. 10710
10.10.2022 10.10.2022 10.10.2022

DESIGNER
FULLER D'ANGELO P.C.A.
ARCHITECTS PLANNERS
405 E. 10TH STREET, SUITE 200
ALBANY, NEW YORK 12206
TEL: 518.486.4444
FAX: 518.486.4444
WWW.FULLERDANGELO.COM
PROJECT NO. 2022-001
SHEET NO. 101 OF 101

DATE
2.9.2022

PROJECT NO.
1000000000

YPS NO.
10001

ADDENDUM 1
3.4.2022

REVISION
ISSUED FOR BID
DRAWN BY
CHECKED BY
SHEET NO.
SCALE

SHEET TITLE
ROOSEVELT HS
FIRST FLOOR
REFLECTED CEILING
PLAN

SHEET NO.
A-201



- CEILING LEGEND

-

NOTES:
1. NOT ALL SYMBOLS ARE NECESSARILY USED ON THIS PROJECT
2. REFER TO MECHANICAL AND ELECTRICAL DRAWINGS FOR ADDITIONAL INFORMATION.

ENGINEER:

ER

Clearbach & Roberts Engineering, P.C.

FULLER
D'ANGELO
P.C.
ARCHITECTS
PLANNERS

48 HOLLYWOOD ROAD
ELMSFORD NEW YORK 10523
TEL 914.898.6666
FAX 914.898.1717
WWW.FULLERDANBELSON
Copyright 2020 All Rights Reserved By
FULLER & D'ANGELO P.C.

CONSULTANT(S):





**YONKERS PUBLIC SCHOOLS
ROOSEVELT HIGH SCHOOL
REPLACEMENT OF CEILINGS AND LIGHTS PHASE II**

10

E&R PROJECT NO.		Y18R00204	
YPS NO.		10891	
ADDENDUM 1		3.4.2022	
REVISION		DATE	BY
ISSUED FOR BID			
DRAWN BY		JMU	
CHECKED BY		JE	
SHEET SIZE		ARCH (8" 3/4" x 4")	
SCALE		AS NOTED	
SHEET TITLE			
ROOSEVELT HS SECOND FLOOR REFLECTED CEILING PLAN			
SHEET NO.			

A-202

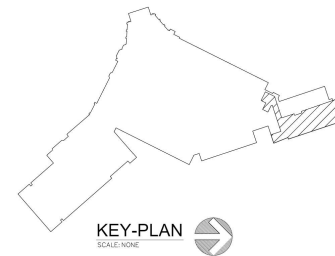

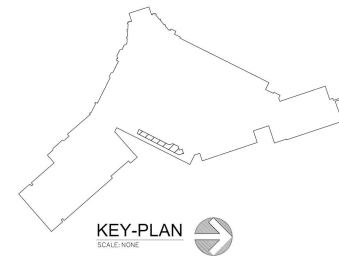



1 PARTIAL BASEMENT FLOOR PLAN - NEW WORK
SCALE: 1/16"=1'-0"

NOTE: FOR ACTUAL CEILING GRID LAYOUT REFER TO
MECHANICAL DRAWINGS

Schedule	Label	Quantity	Description	Quantity	Notes	Notes	Notes	Notes	Notes	Notes
1	D	1	0018 SERVICE AREA	1	0018 SERVICE AREA	1	0018 SERVICE AREA	1	0018 SERVICE AREA	1
2	E	1	0019 PUMP AREA	1	0019 PUMP AREA	1	0019 PUMP AREA	1	0019 PUMP AREA	1

EM - EMERGENCY BATTERY BACKUP



KEY-PLAN
SCALE: NONE

OWNER:
Fuller & Baker Engineering, P.C.
200 West 10th Street, Suite 100
New York, NY 10011
Tel: 212.691.1000
Fax: 212.691.1001
www.fullerandbaker.com

CONSULTANT:
FULLER & BAKER
P.C.
ARCHITECTS
PLANNERS

AS NOTED, UNLESS NOTED
ELSEWHERE NEW WORK IS TO BE
IN ACCORDANCE WITH THE
NEW YORK STATE DESIGN
LAW, 2010, 2011, 2012, 2013
AND 2014, 2015, 2016, 2017, 2018
AND 2019, 2020, 2021, 2022, 2023
AND 2024, 2025, 2026, 2027, 2028
AND 3764, 3765, 3766, 3767, 3768
AND 3769, 3770, 3771, 3772, 377



Symbol	Label	Category	Description	Catalog Number	Description	Lamp	Number	Distance	Lumen Per Lamp	Light Loss Factor	Voltage
	A	SEE LAMP	Johnson Lighting	SPINAL 20 3400LM RCTH 40W 4000K	SPINAL 20 3000 RCTH 40W 4000K		1	SPINAL_20_3400LM_RCTH_40W_4000K	3100	0.9	24.9V
	B	SEE LAMP	JOHNSON LIGHTING	SPINAL 20 3400LM RCTH 40W 4000K	SPINAL 20 3000 RCTH 40W 4000K		1	SPINAL_20_3400LM_RCTH_40W_4000K	3100	0.9	24.9V
	C	SEE LAMP	JOHNSON LIGHTING	SPINAL 20 3400LM RCTH 40W 4000K	SPINAL 20 3000 RCTH 40W 4000K		1	SPINAL_20_3400LM_RCTH_40W_4000K	3100	0.9	24.9V
	D	SEE LAMP	JOHNSON LIGHTING	SPINAL 20 3400LM RCTH 40W 4000K	SPINAL 20 3000 RCTH 40W 4000K		1	SPINAL_20_3400LM_RCTH_40W_4000K	3100	0.9	24.9V

KEY-PLAN
SCALE: NONE