


KEY MAP
SCALE: 1" = 1,500'

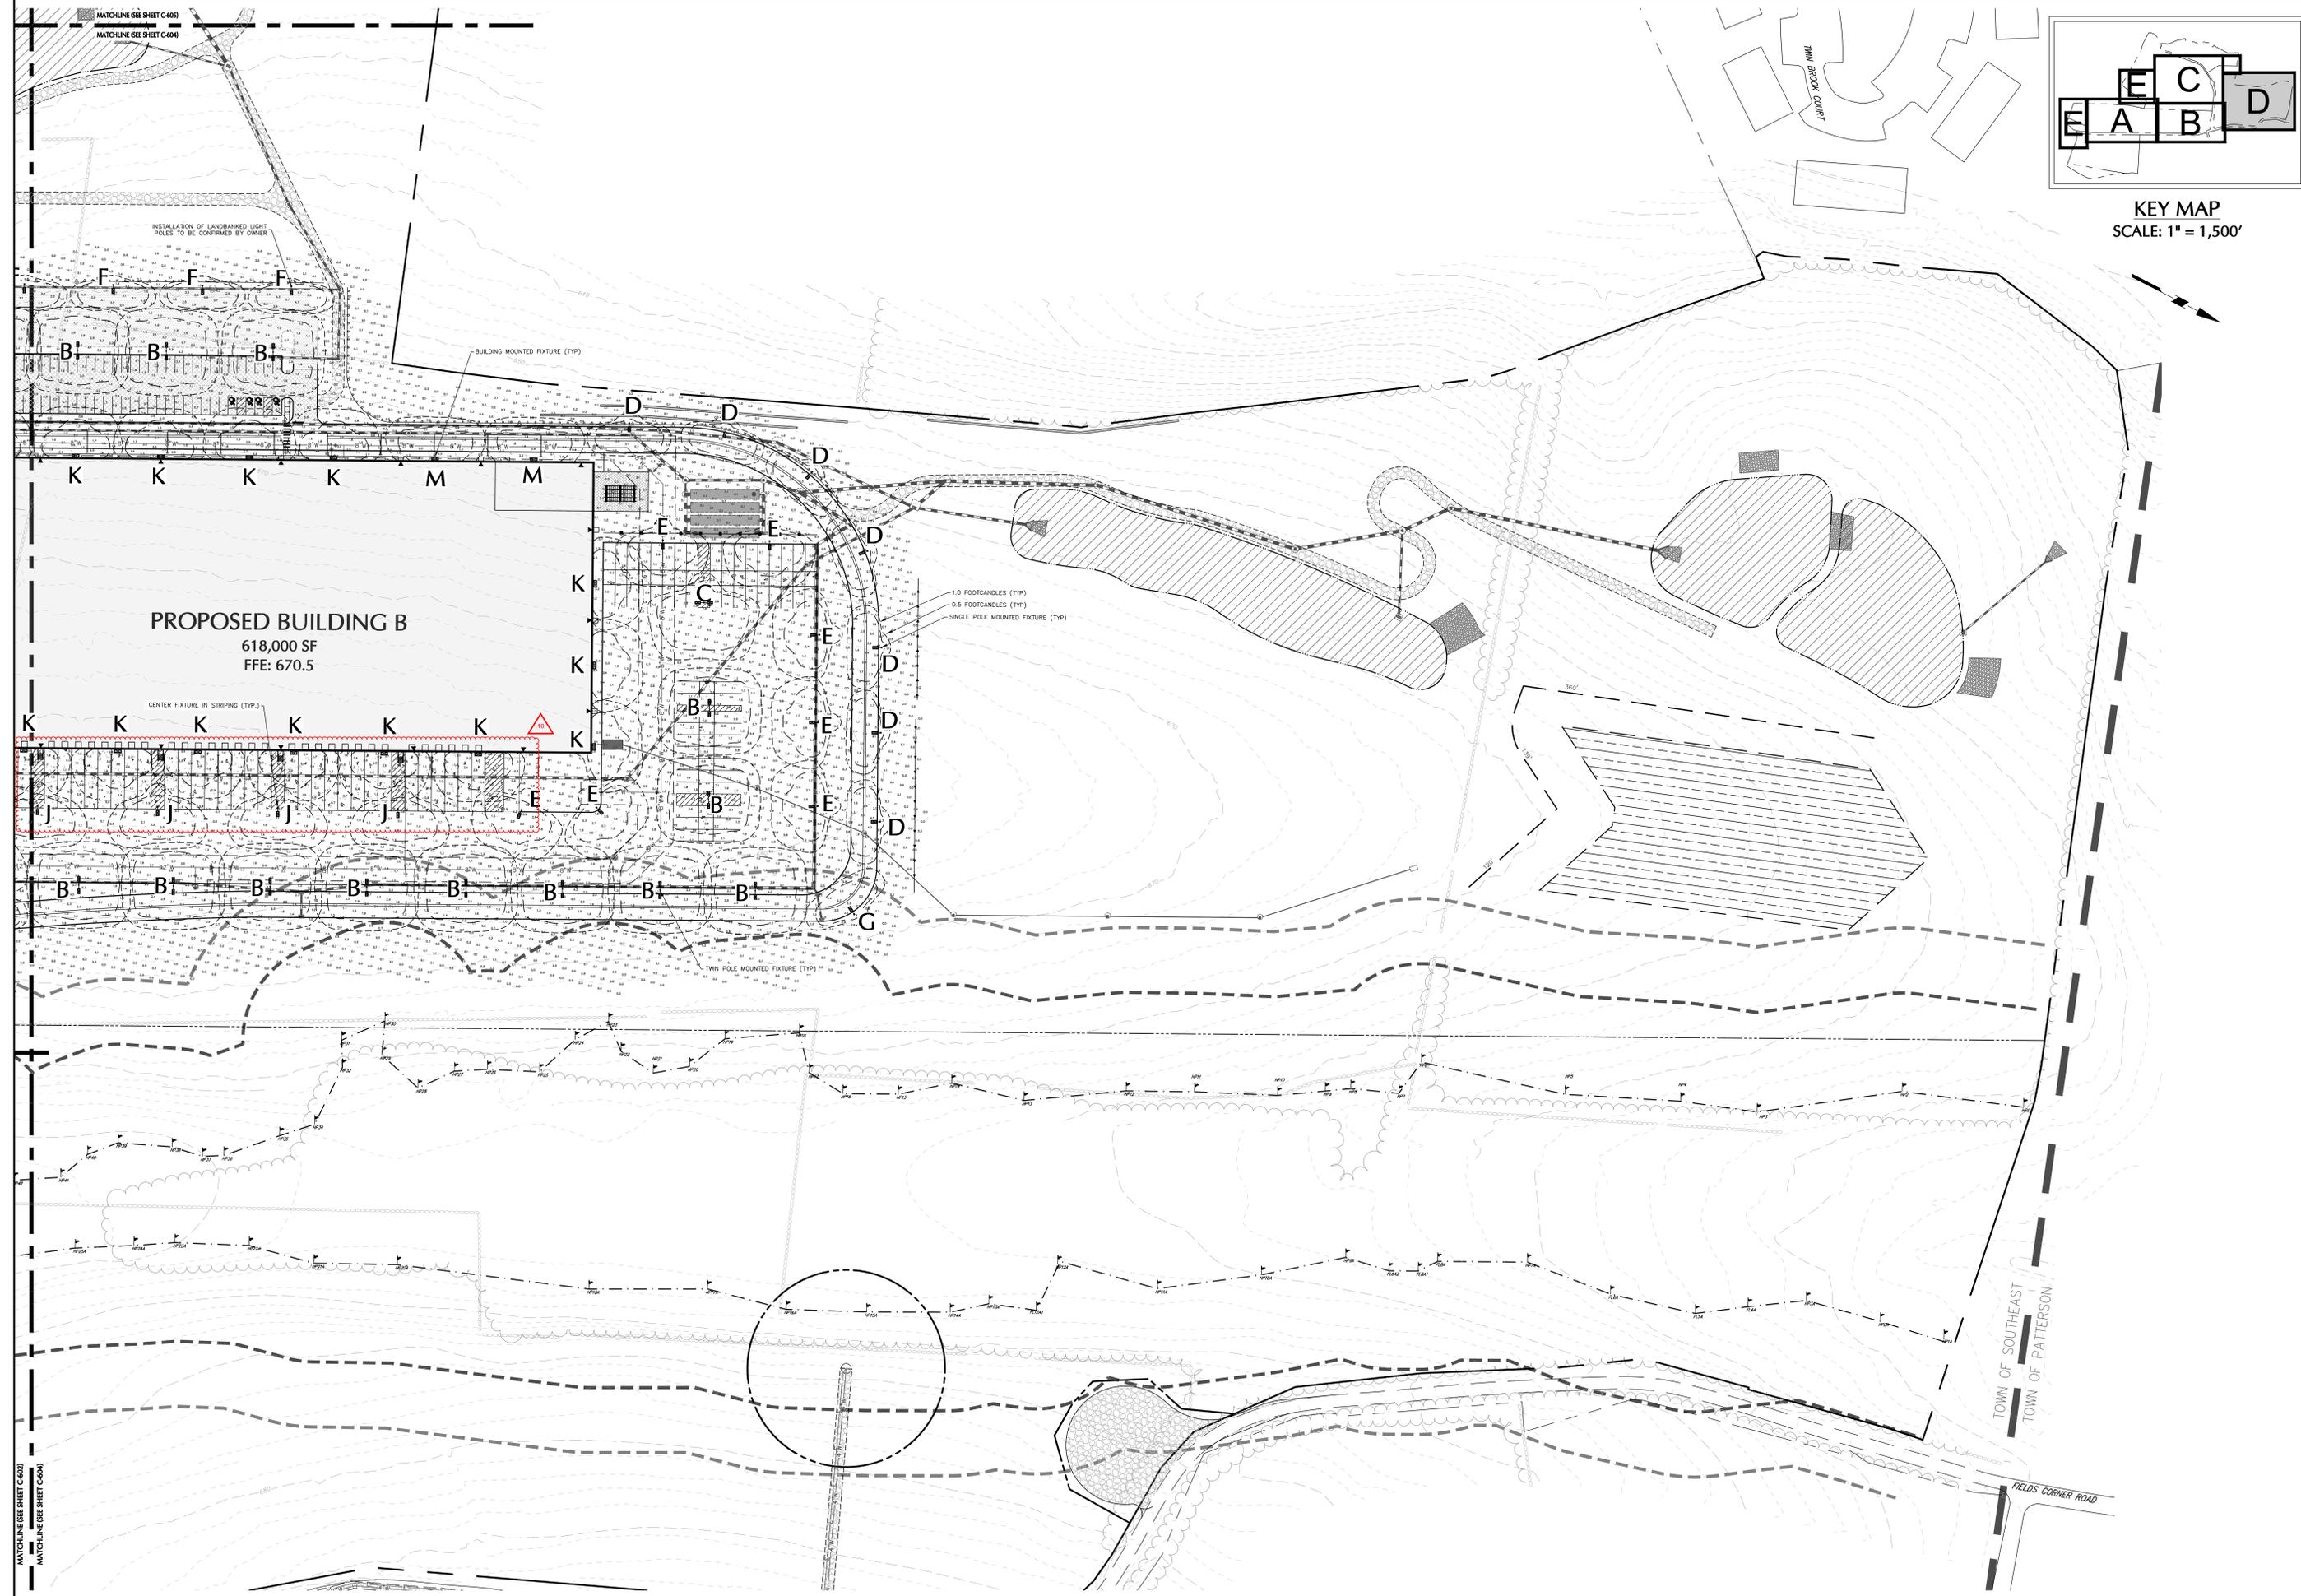

PROPOSED BUILDING B
618,000 SF
FFE: 670.5

1.0 FOOTCANDLES (TYP)
0.5 FOOTCANDLES (TYP)
SINGLE POLE MOUNTED FIXTURE (TYP)

TWIN POLE MOUNTED FIXTURE (TYP)

Date	Description	No.	Date	Description	No.
03/06/2023	REVISED BUILDING B STORM ROOF LEADERS	8			
02/10/2023	REV. NEW LOT LINE / SITE GRADING & STORM	7			
12/30/2022	REV. BUILDING A UTILITIES	6			
12/16/2022	REV. PER WATERSHED INSPECTOR GENERAL COMMENTS	5			

SCALE IN FEET
0 10 20 50

WARNING: IT IS A VIOLATION OF THE NYS EDUCATION LAW ARTICLE 145 FOR ANY PERSON, UNLESS HE IS ACTING UNDER THE DIRECTION OF A LICENSED PROFESSIONAL ENGINEER, LAND SURVEYOR OR GEOLOGIST, TO ALTER THIS ITEM IN ANY WAY.

05/25/2023

LANGAN
Langan Engineering, Environmental, Surveying, Landscape Architecture, and Geology, D.P.C.
One North Broadway, Suite 910
White Plains, NY 10601
T: 914.323.7400 F: 914.323.7401 www.langan.com

Project
LINCOLN LOGISTICS BREWSTER
TOWN OF SOUTHEAST PUTNAM COUNTY NEW YORK

Drawing Title
LIGHTING PLAN D

Project No. 190065201
Date 1/28/2022
Drawn By MJ
Checked By MH
Drawing No. C-604
Sheet 65 of 96