




SUBMITTALS

NO.	DATE	DESCRIPTION
A	05.27.22	ISSUE FOR REVIEW
0	06.10.22	ISSUE FOR PERMIT

PROJECT NO.  
 AS286-21/ NY131

DRAWN BY  
 FXB

SHEET TITLE  
**ELECTRICAL  
 SITE PLAN**

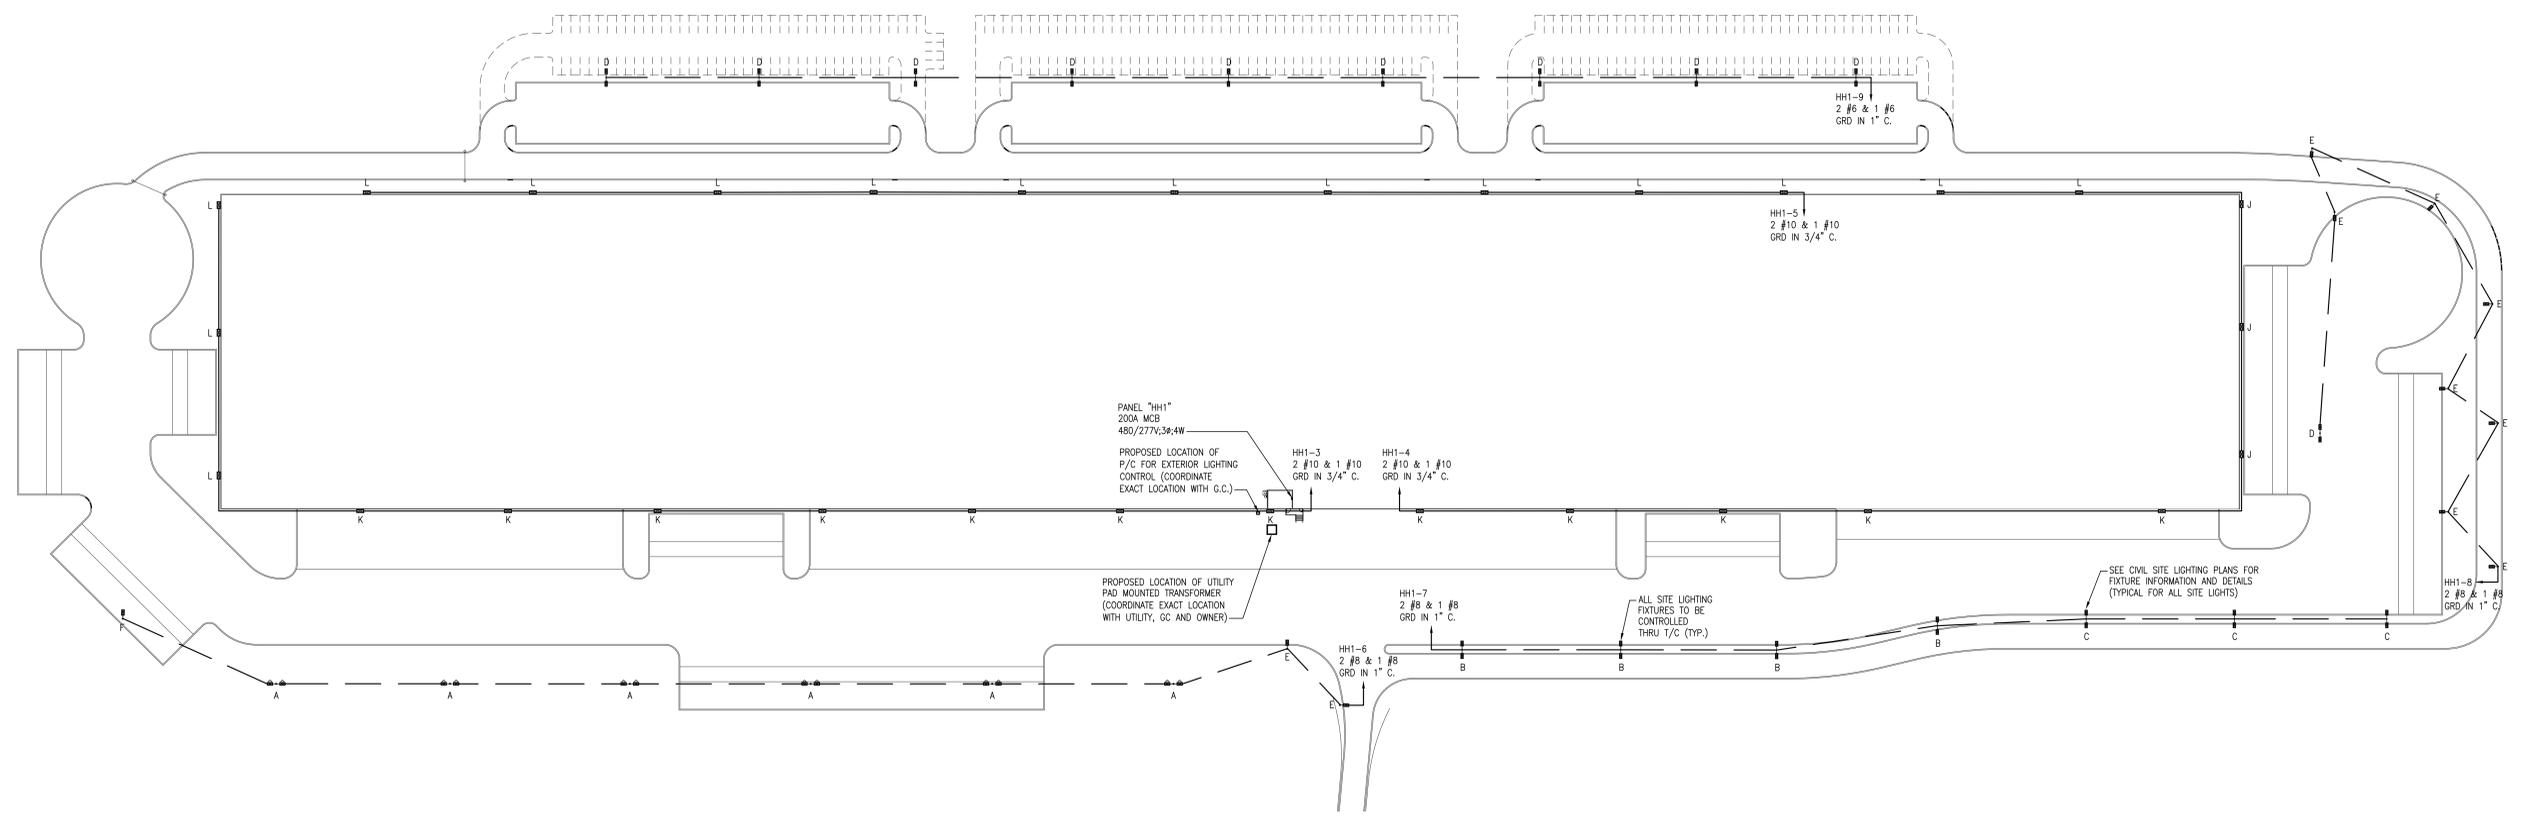

**1 ELECTRICAL SITE PLAN**  
 ESP1.0 SCALE: 1" = 70'-0"  
 NOTES:  
 1. ALL SHOWN IS NEW & BY EC UNLESS SPECIFICALLY NOTED OTHERWISE.