

IT IS A VIOLATION OF STATE EDUCATION LAW FOR ANY PERSON, UNLESS UNDER THE DIRECTION OF A LICENSED ARCHITECT/ENGINEER TO ALTER THIS DOCUMENT IN ANYWAY. ALTERATIONS MUST HAVE THE SEAL AFFIXED ALONG WITH A DESCRIPTION OF THE ALTERATIONS, DATE AND ARCHITECTS/ENGINEERS SIGNATURE. COPYRIGHT © 2023

Architect:
Saratoga Associates
21 Congress Street, Suite 201
Saratoga Springs, NY 12866

SARATOGA ASSOCIATES
Landscape Architects, Architects
Engineers, and Planners, P.C.

Surveyor/ Structural/ MEP Engineer:
LaBella Associates
105 N. Tioga Street, Suite 200
Ithaca, NY 14850

LaBella

Certificate of Authorization Number:
Professional Engineering 018281
Land Surveying 017878
Geological 018750

Palisades Region
Palisades Interstate Park Commission
Bear Mountain, New York 10911
(845) 786-2701
Executive Director: Joshua Laird

Project Title:
CAMP JUNIOR ON LAKE TIORATI -
PHASE 3

Project Location:
HARRIMAN STATE PARK

Key Plan

REVISIONS

Rev No	Description	Date

Drawn By:
KET, LLH

Design By:
LLH

Checked By:
CTS

Approved By:
CTS

Date:
3/16/23

Seal and Signature




Sheet Title:
**RCP & ROOF PLAN -
BATHHOUSE
#231 & #322**

Drawing Number:
A110


Bid Documents

Project Number:
21059.23

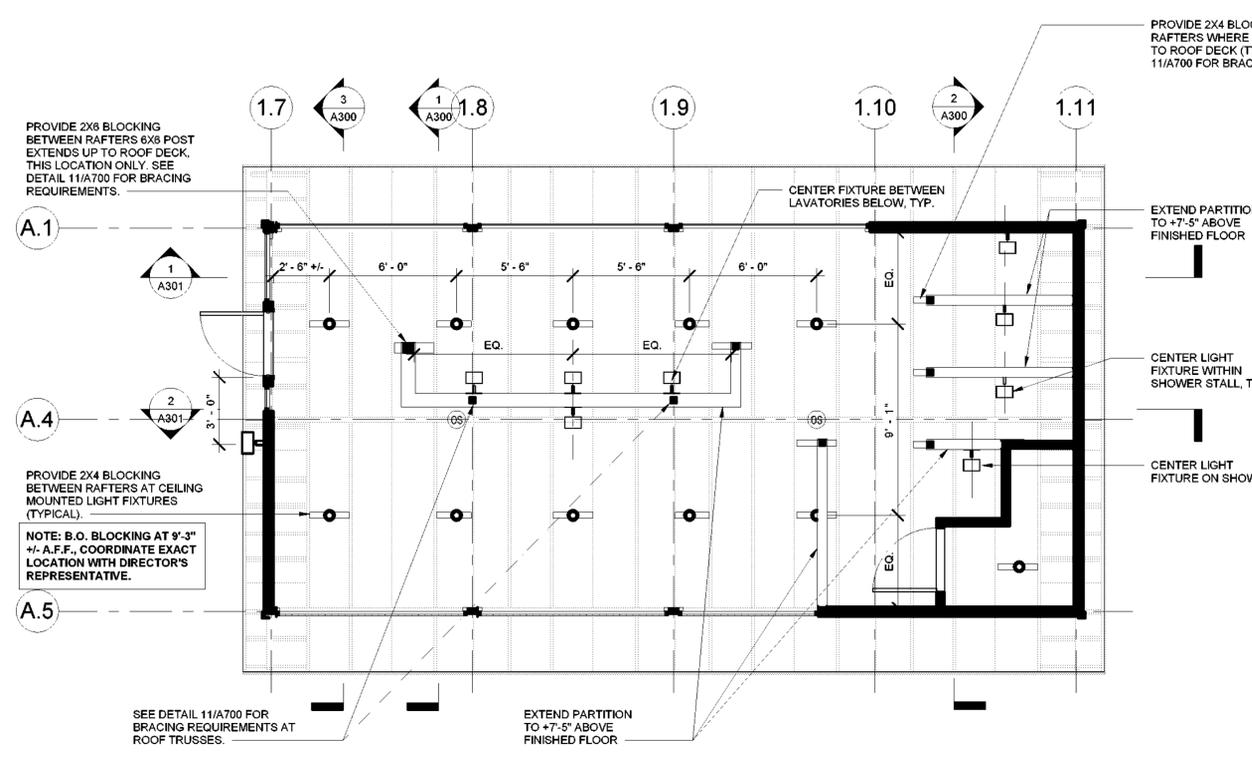


1 REFLECTED CEILING PLAN BATHHOUSE #231 & #322
1/4" = 1'-0"

- GENERAL NOTES**
- ALL DIMENSIONS INDICATE CENTER LINE OF FIXTURE OR FACE OF WALL FINISH, UNLESS OTHERWISE NOTED.
 - CENTER CEILING MOUNTED LIGHT FIXTURES BETWEEN RAFTERS (TYPICAL).
 - SEE ELECT. DWGS FOR LIGHTING FIXTURE TYPES.
 - SEE STRUCTURAL DRAWINGS FOR FRAMING PLAN.
- RCP SYMBOL LEGEND**
- CEILING MOUNTED LIGHT FIXTURE (SURFACE MOUNTED)
 - WALL MOUNTED LIGHT FIXTURE
 - OS OCCUPANCY SENSOR
 - ⚡ EMERGENCY LIGHT FIXTURE

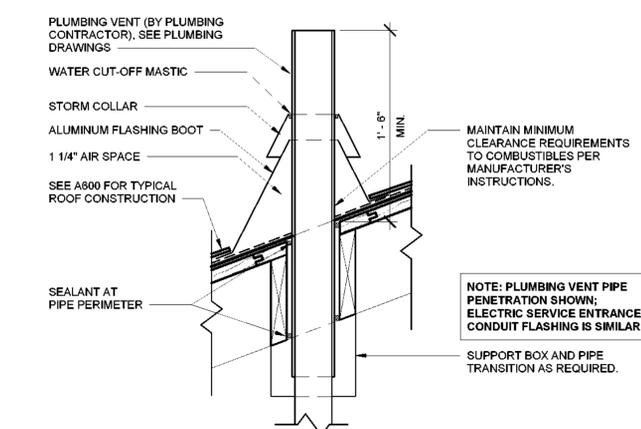

3 TYP. PIPE PENETRATION FLASHING DETAIL
1 1/2" = 1'-0"

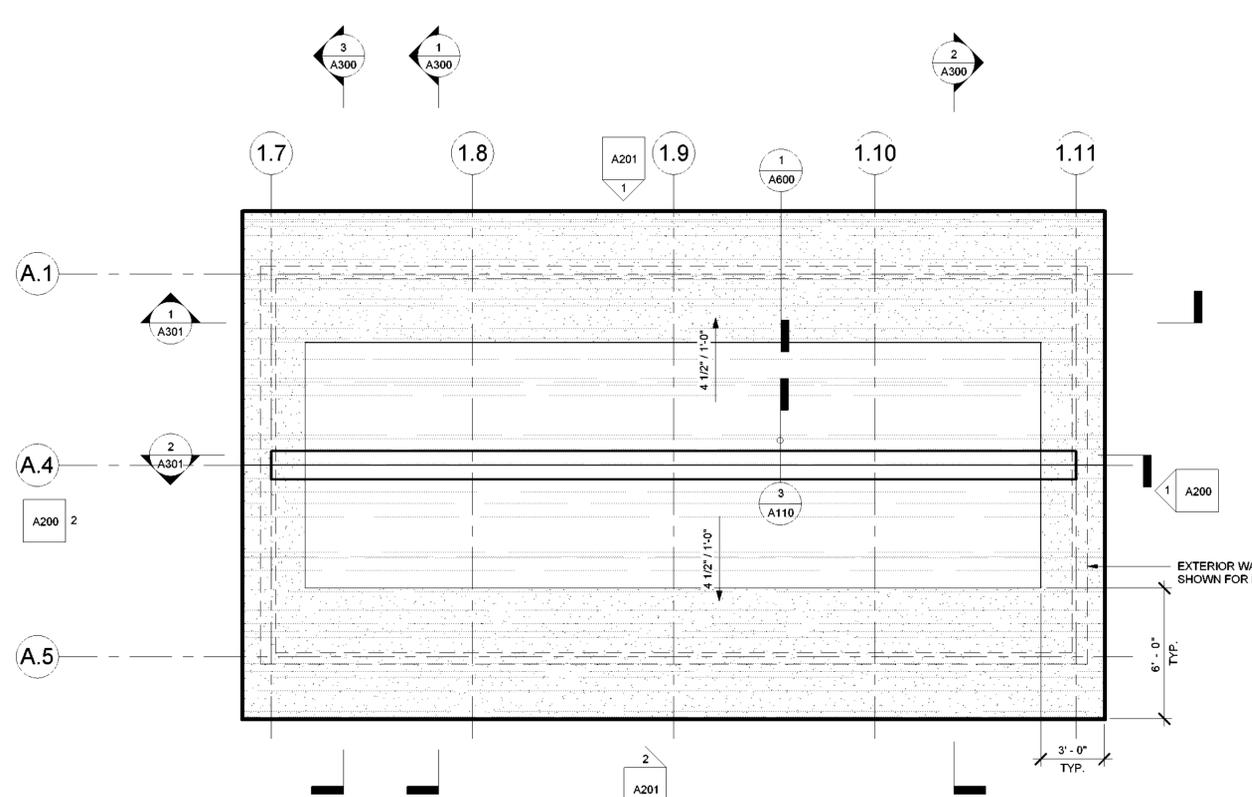

2 ROOF PLAN BATHHOUSE #231 & #322
1/4" = 1'-0"

- GENERAL ROOF NOTES**
- COORDINATE WORK WITH OTHER TRADES WHERE SPECIFIC DETAILS ARE NOT INDICATED. PROVIDE MANUFACTURER'S STANDARD ROOFING DETAILS AT ALL PENETRATIONS, TERMINATIONS AND TRANSITIONS.
 - ICE & WATER SHIELD IS TO BE APPLIED AROUND ALL ROOF PENETRATIONS, ROOF OPENINGS, AND AT ALL ROOF EDGES. PRODUCT IS TO BE INSTALLED PER MANUFACTURER'S DIRECTION.
- ROOF PLAN SYMBOL LEGEND**
- ▨ ASPHALT SHINGLE ROOF
 - ▨ ICE & WATER SHIELD
 - - - WALL BELOW
 - ROOF SLOPE
 - EXHAUST VENT, SEE MECHANICAL DRAWINGS