General Notes:

IN ALL AREAS WITH EXISTING CEILINGS TO REMAIN, ELECTRICAL CONTRACTOR IS RESPONSIBLE TO REMOVE AND REINSTALL CEILING TILES


2. WALL MOUNTED EMERGENCY LIGHTING IN CORRIDORS IS EXISTING TO

3. WALL MOUNTED EXIT LIGHTING IN CORRIDORS IS EXISTING TO REMAIN

LIGHTING, WIRING, CONDUIT, JUNCTION BOXES, ETC.

REMAIN WHERE SHOWN ON THE PLANS.

AND GRID AS NECESSARY TO COMPLETE REMOVAL AND INSTALLATION OF

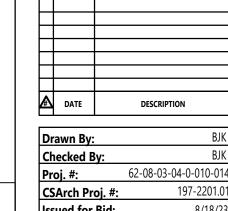

KEY PLAN

 Checked By:
 BJK


 Proj. #:
 62-08-03-04-0-010-014

 CSArch Proj. #:
 197-2201.01

 Issued for Bid:
 8/18/23
AREA C FIRST

FLOOR LIGHTING PLAN

CONSTRUCTION DOCUMENTS

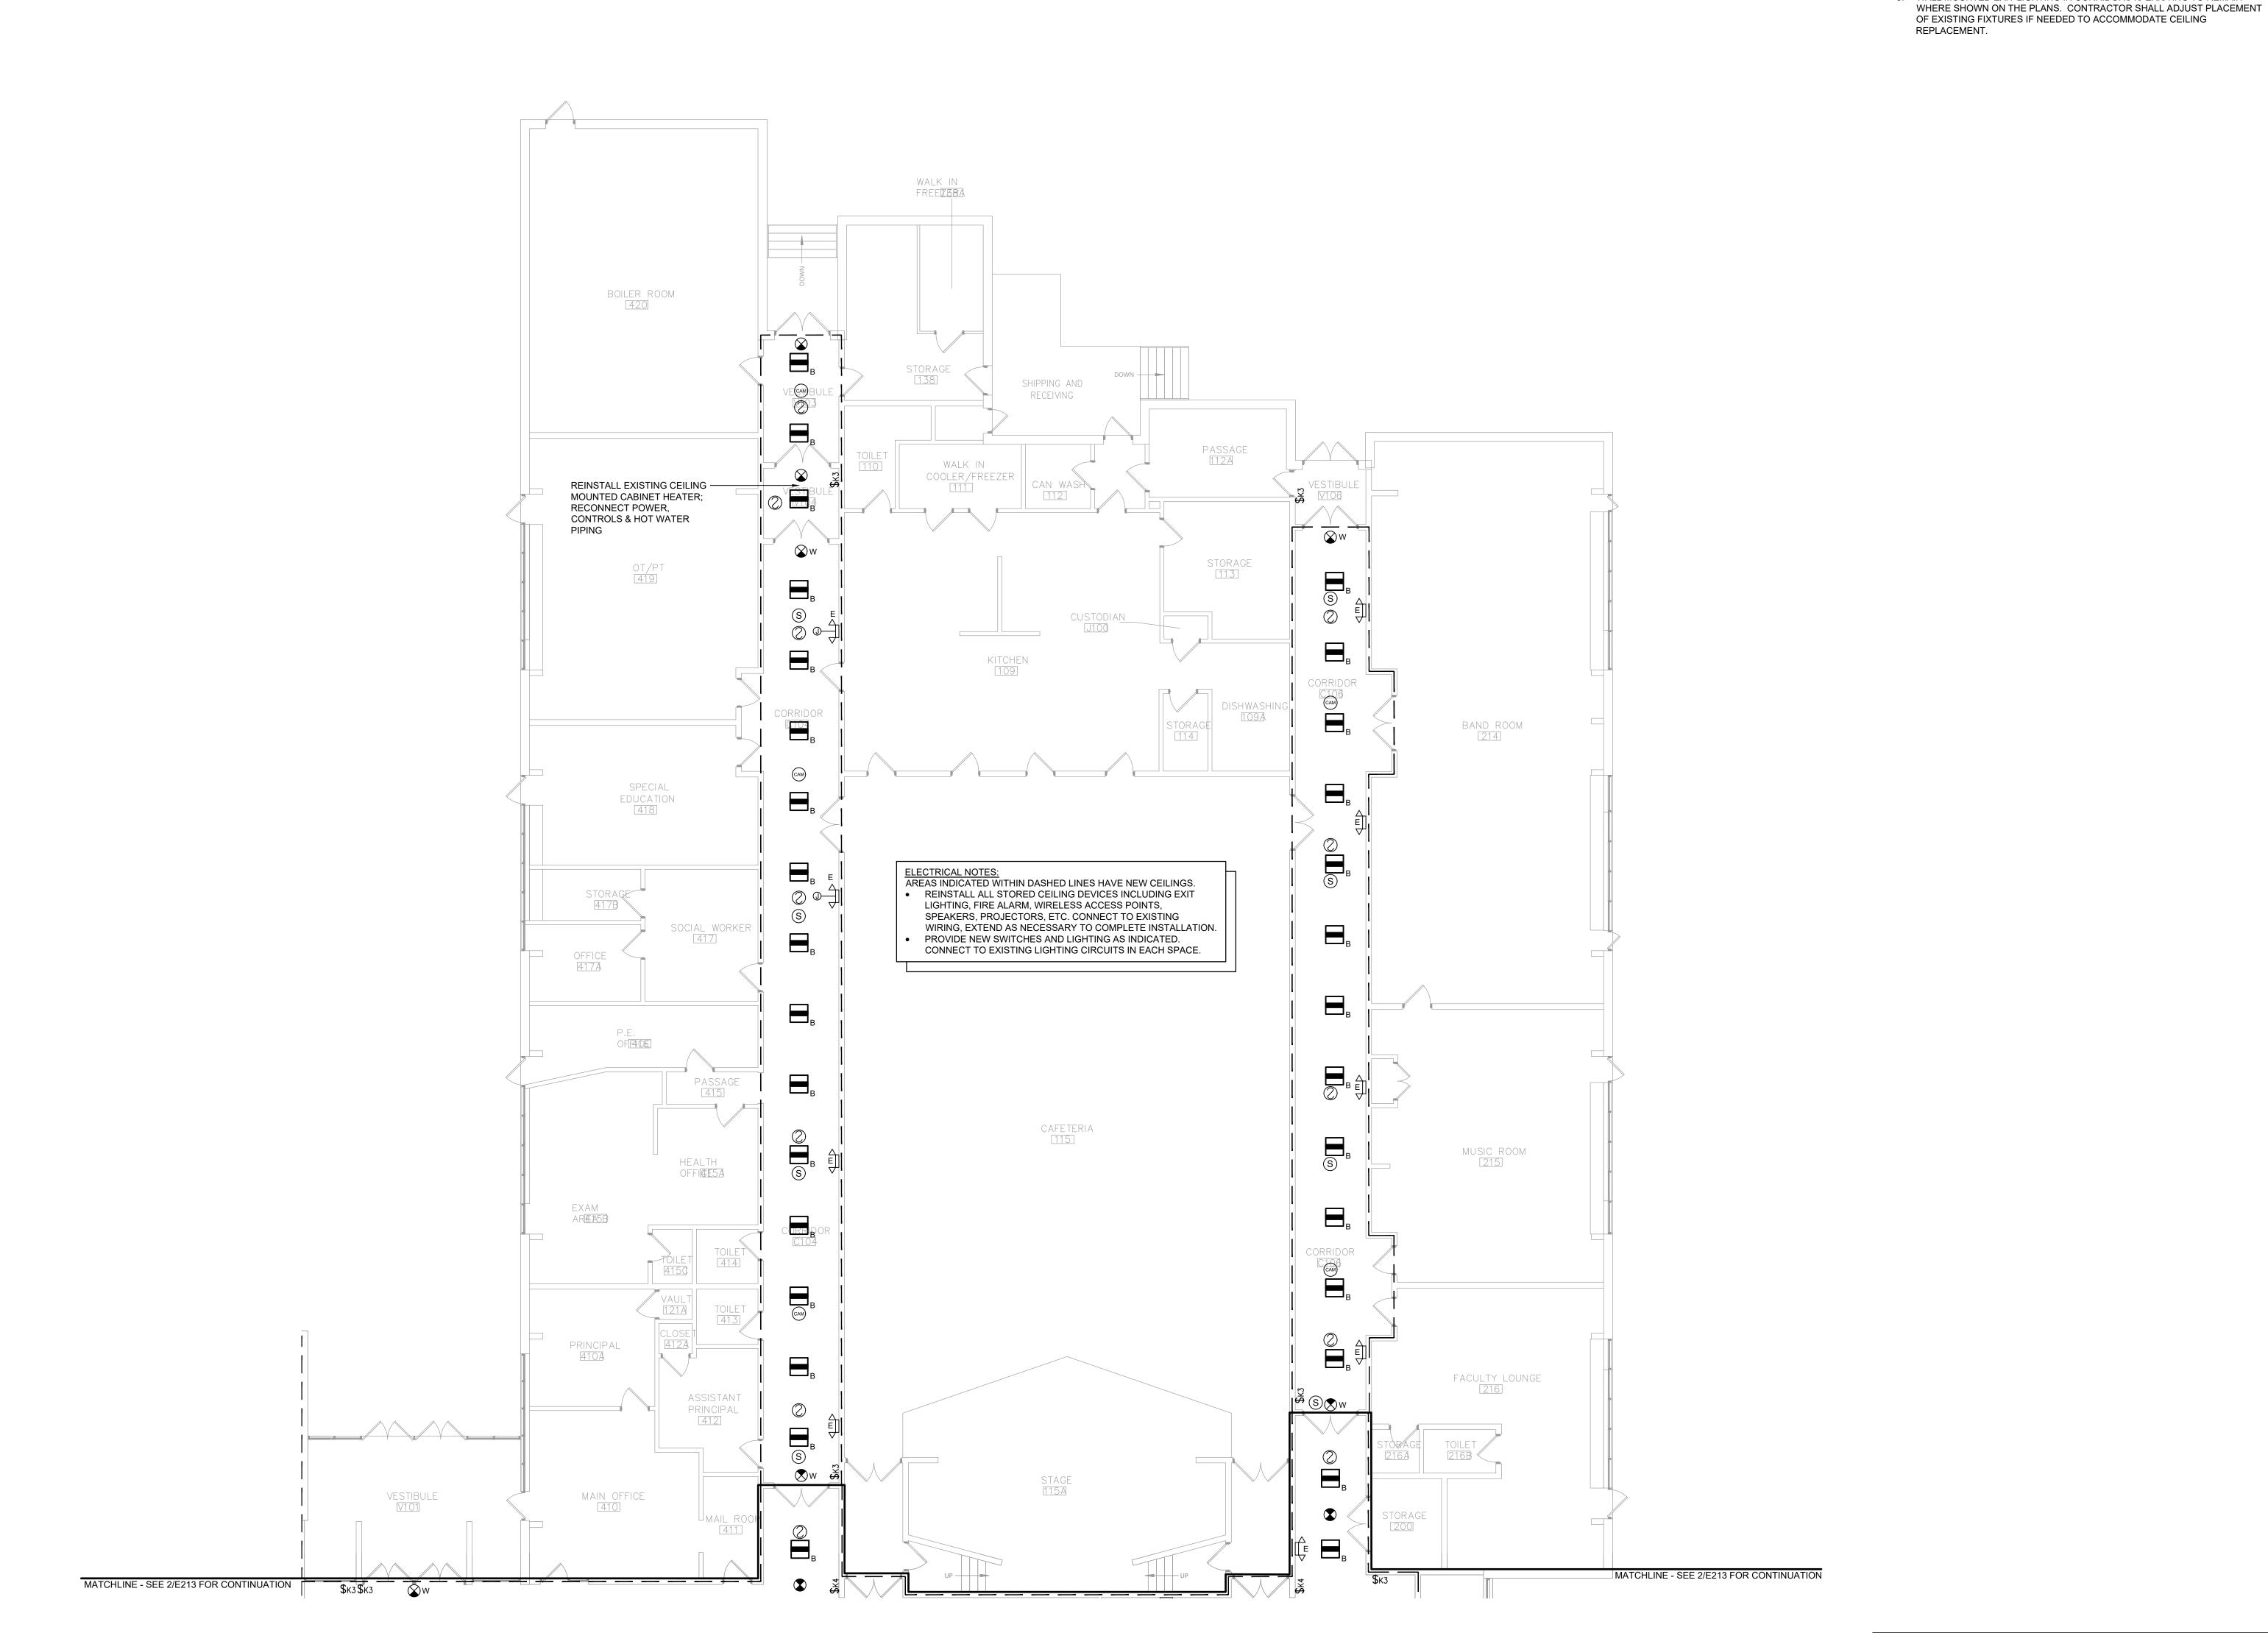

Area C First Floor Lighting Plan E212 Scale: 1/8" = 1'-0"