




*Peter J. Bonner*

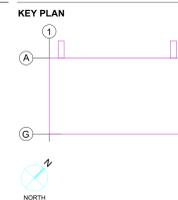

SUBMITTALS


NO.	DATE	DESCRIPTION
A	11.20.2024	ISSUE FOR REVIEW
B	02.02.2024	ISSUE FOR REVIEW
0	02.09.2024	ISSUE FOR PERMIT

PROJECT NO. AS397-22 | NY154  
 DRAWN BY NGF

SHEET TITLE  
**ELECTRICAL SITE LIGHTING PLAN**

SHEET NO.

**ESP1.0**

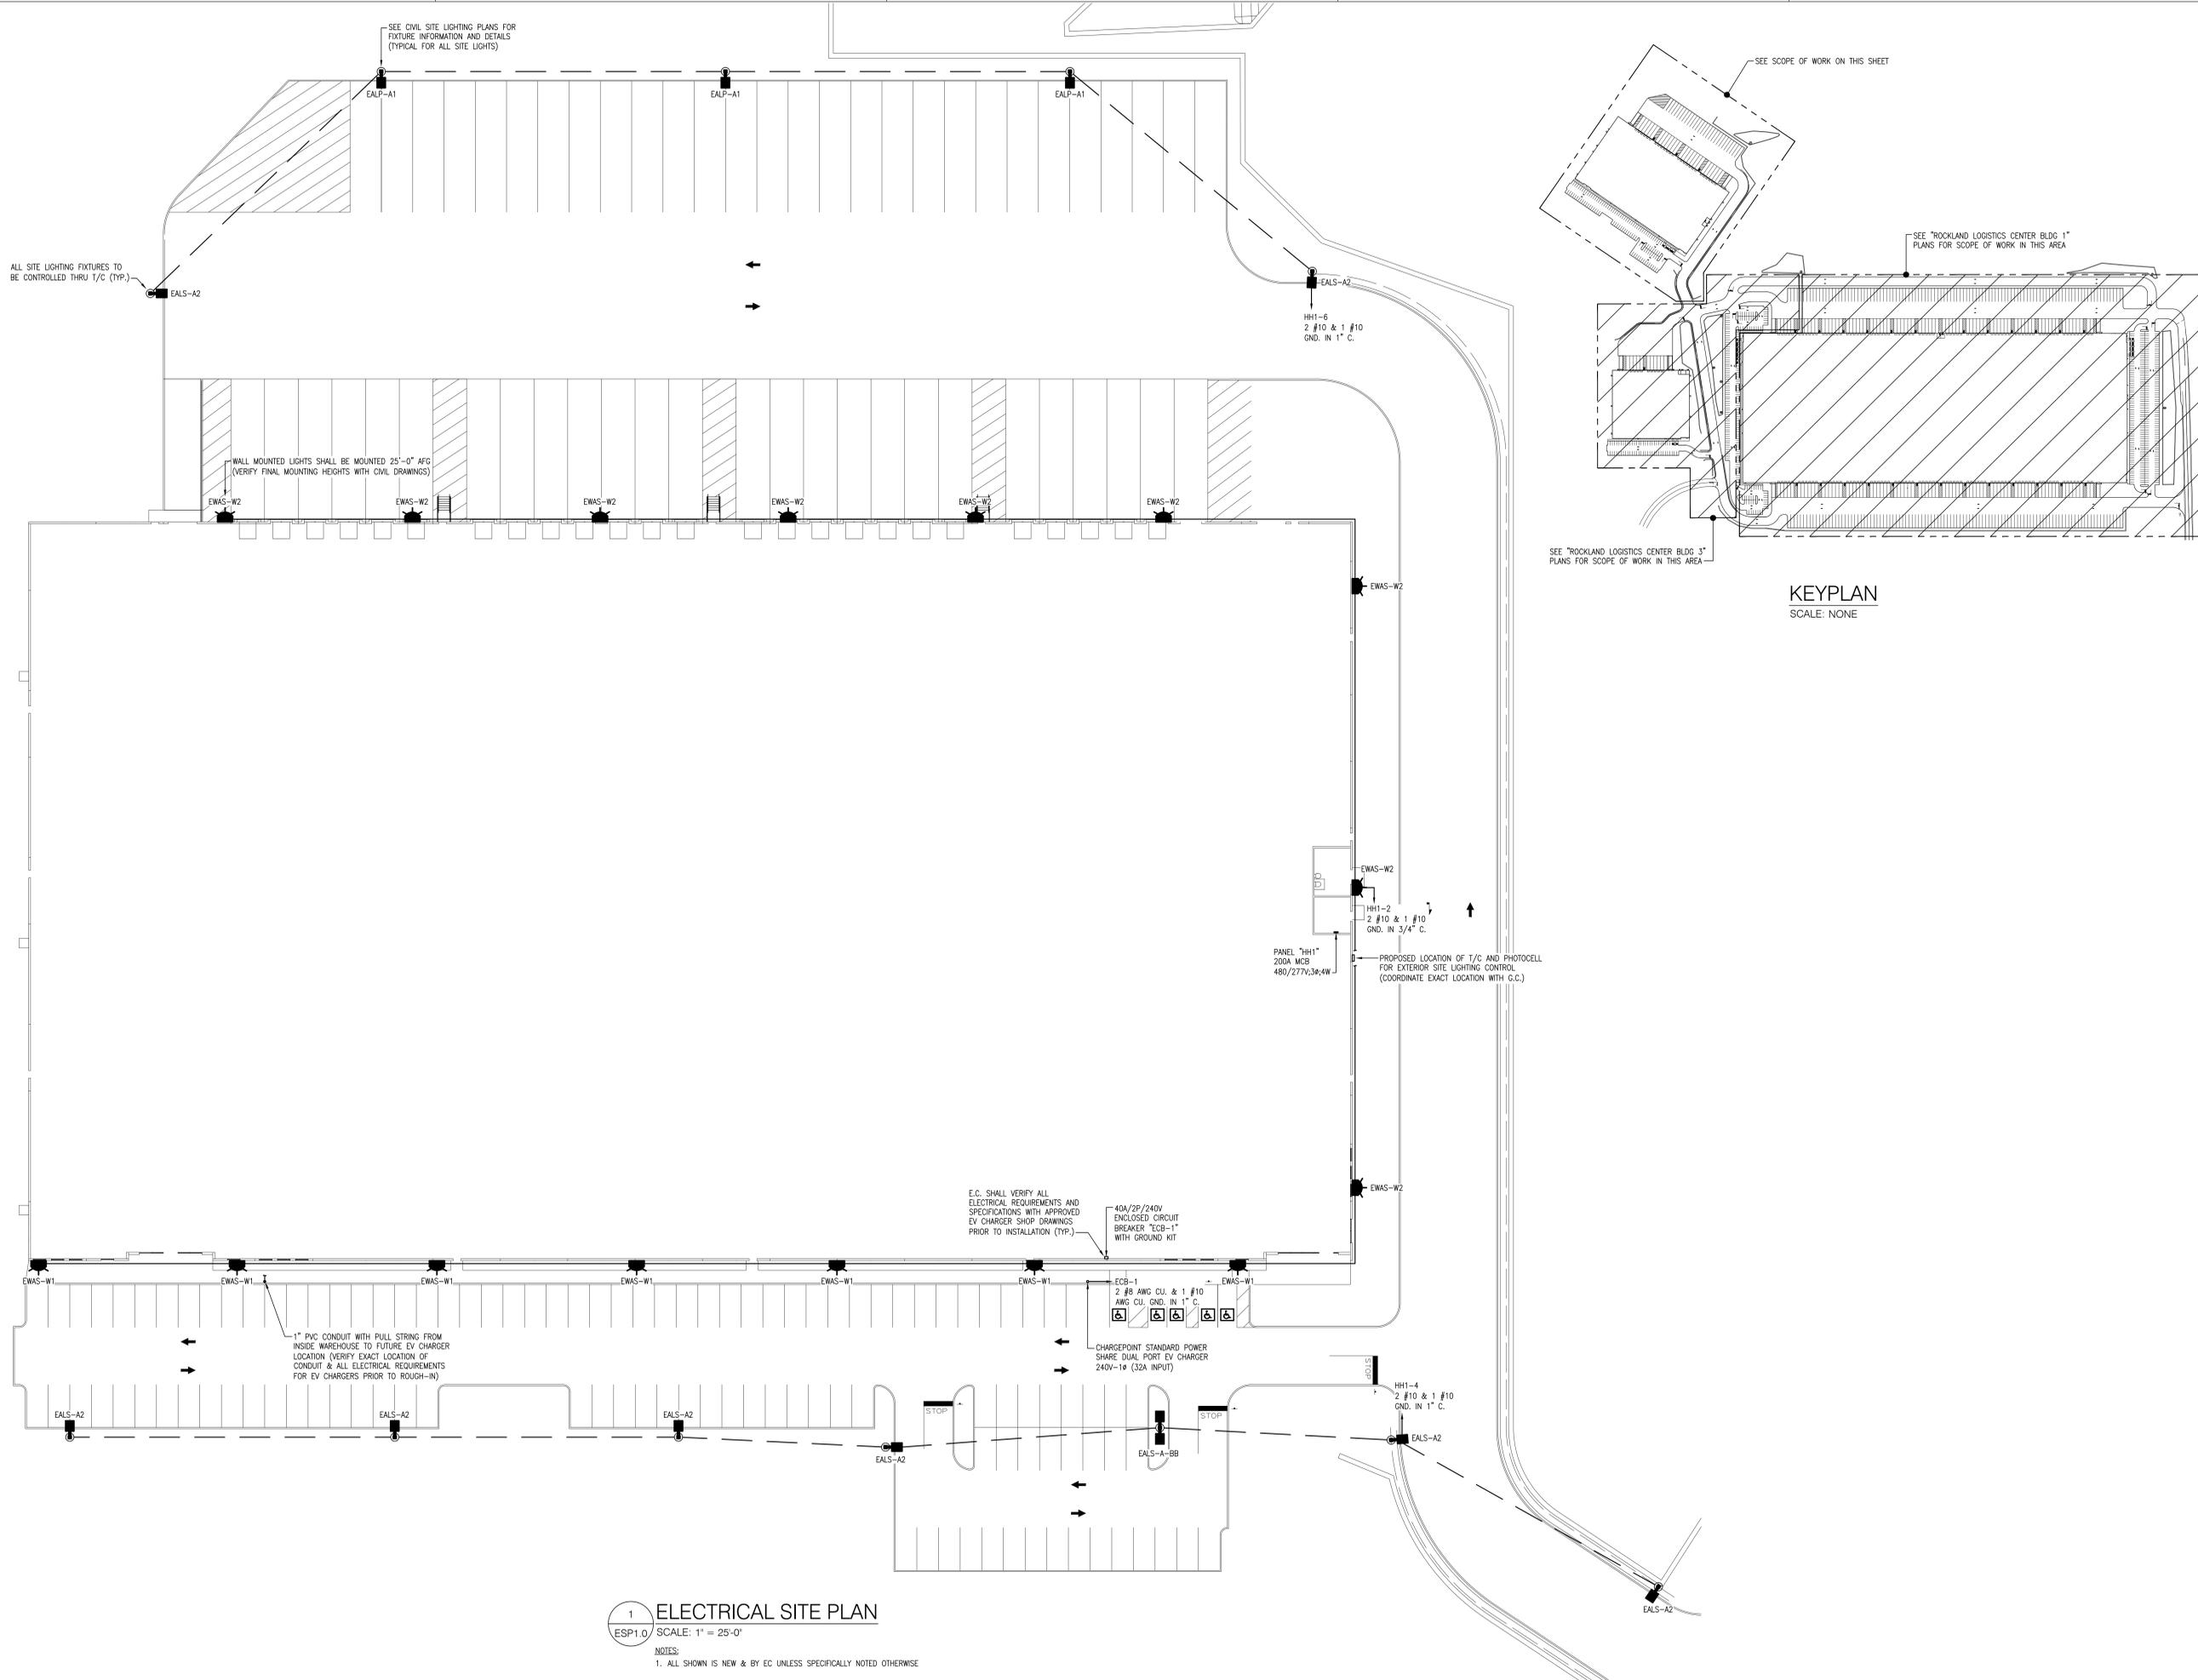

**1** ELECTRICAL SITE PLAN  
 ESP1.0 SCALE: 1" = 25'-0"

NOTES:  
 1. ALL SHOWN IS NEW & BY EC UNLESS SPECIFICALLY NOTED OTHERWISE