




Peter J. Bonni

KEY PLAN

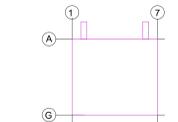

SUBMITTALS

NO.	DATE	DESCRIPTION
A	11.20.2024	ISSUE FOR REVIEW
B	02.02.2024	ISSUE FOR REVIEW
0	02.09.2024	ISSUE FOR PERMIT


PROJECT NO. AS397-22 | NY154

DRAWN BY NGF

SHEET TITLE
ELECTRICAL SITE LIGHTING PLAN

SHEET NO.

ESP1.0

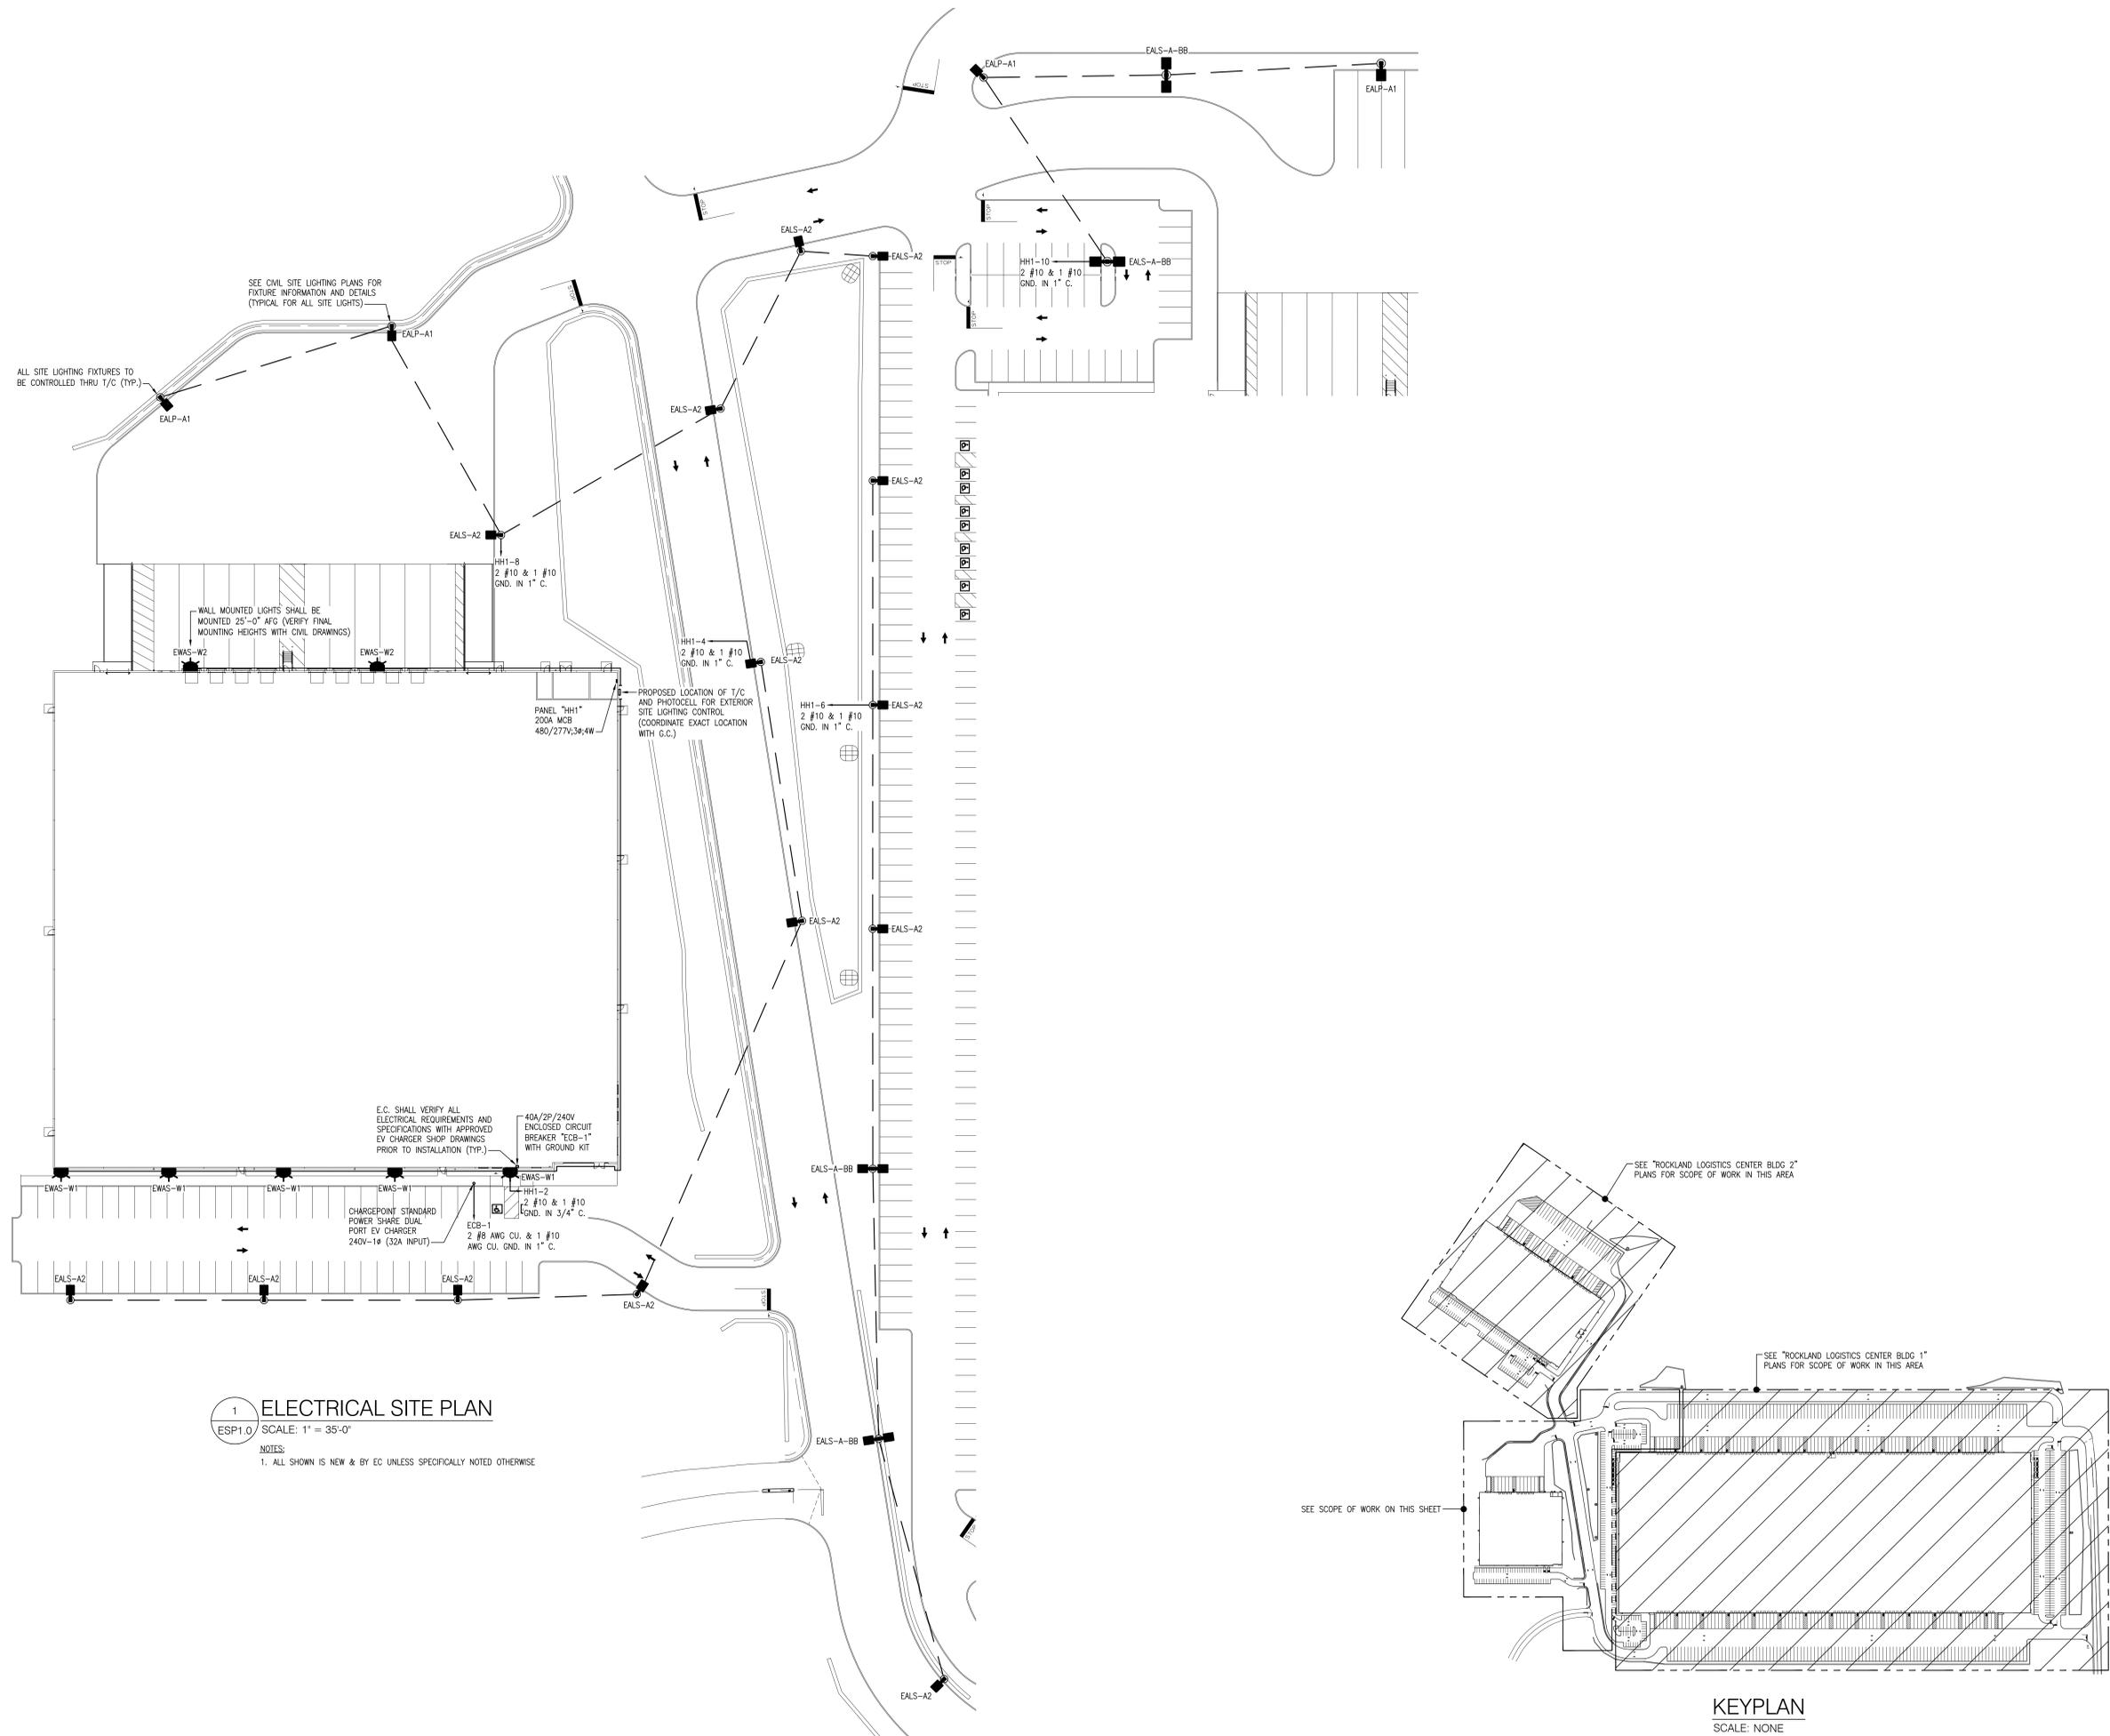

1 ELECTRICAL SITE PLAN
 ESP1.0 SCALE: 1" = 35'-0"

NOTES:
 1. ALL SHOWN IS NEW & BY EC UNLESS SPECIFICALLY NOTED OTHERWISE

