


NOTES:
IT IS A VIOLATION OF THE LAW FOR ANY PERSON, UNLESS ACTING UNDER THE DIRECTION OF A LICENSED ARCHITECT OR ENGINEER TO ALTER AN ITEM IN ANY WAY. IF AN ITEM BEARING THE SEAL OF AN ARCHITECT OR ENGINEER IS ALTERED, THE ALTERING ARCHITECT OR ENGINEER SHALL AFFIX TO HIS ITEM THE SEAL AND THE NOTATION ALTERED BY FOLLOWED BY HIS SIGNATURE AND THE DATE OF SUCH ALTERATION, AND A SPECIFIC DESCRIPTION OF THE ALTERATION.
DO NOT SCALE DRAWINGS. WRITTEN DIMENSIONS GOVERN.
© JOSEPH G THOMPSON ARCHITECT, PLLC. ALL RIGHTS RESERVED.



PEEKSKILL FIREHOUSE KITCHEN INCUBATOR
City of Peekskill (Owner)
701 Washington Street
Peekskill, New York 10566
S-B-L: 32-20-9-1
City of Peekskill - Westchester County

DRAFT CONSTRUCTION DOCUMENT - NOT FOR PERMIT OR CONSTRUCTION

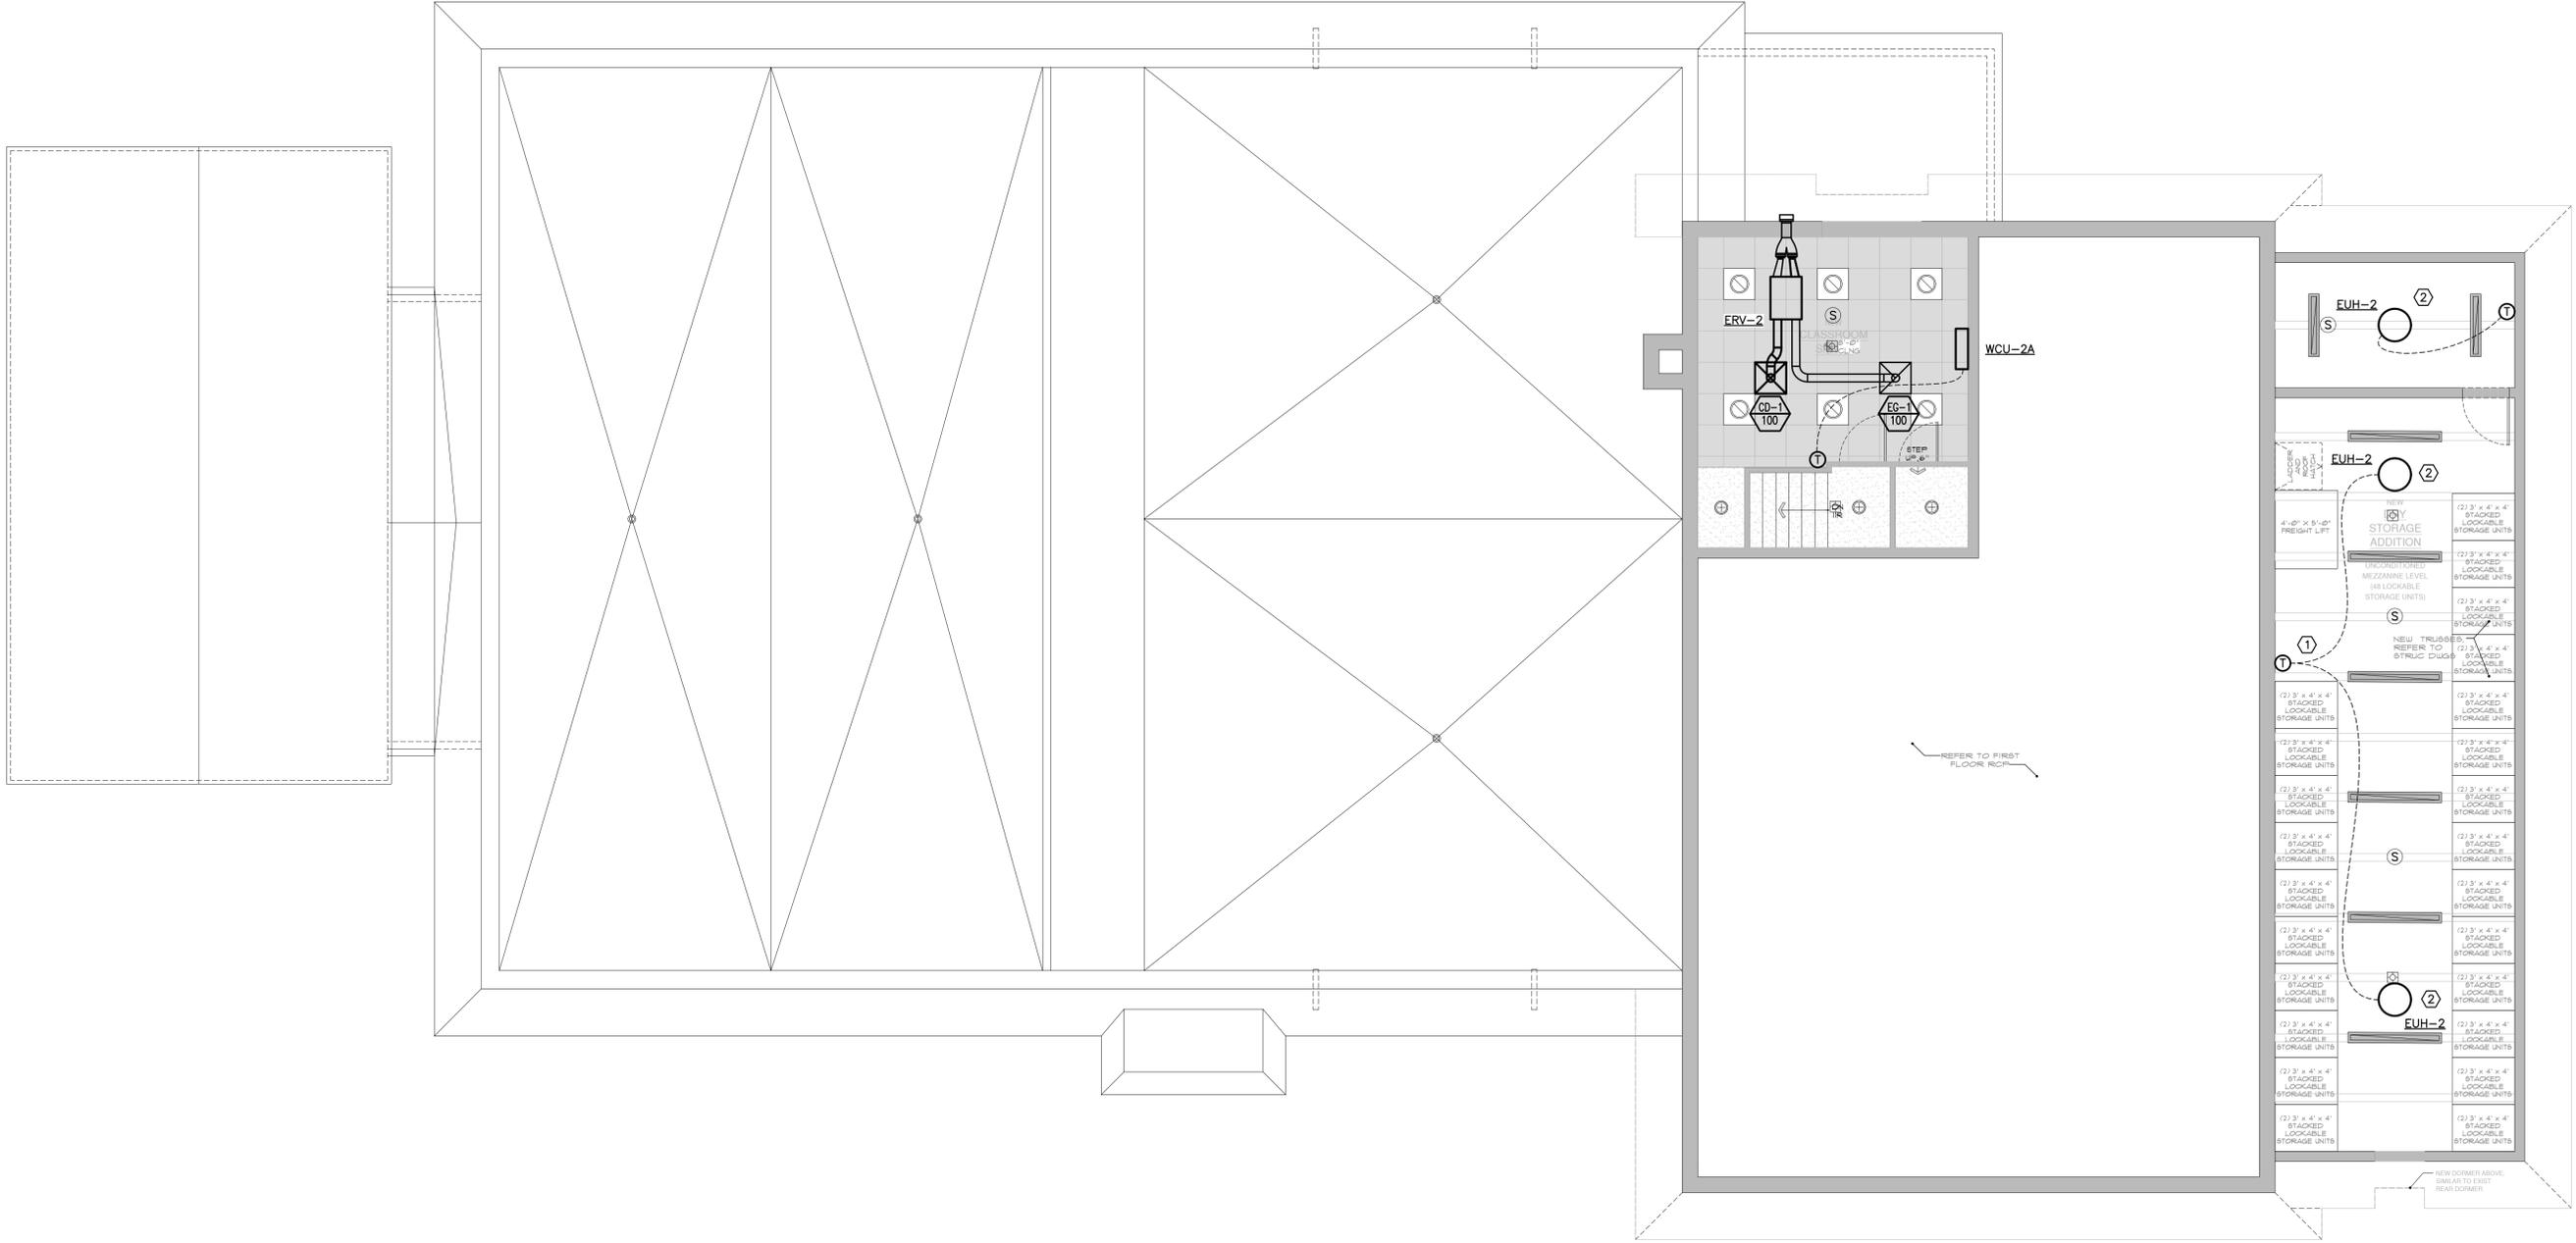

1 HVAC: CONSTRUCTION SECOND FLOOR DUCTWORK PLAN

SCALE: 3/16"=1'-0"

GENERAL NOTES:

1. INSTALL ERV WEATHER HOODS PER MANUFACTURER'S RECOMMENDATIONS.
2. INSULATE AND INSTALL ALL REFRIGERANT PIPING PER MANUFACTURER'S RECOMMENDATIONS.
3. PROVIDE WEATHER SLEEVE FOR EXTERIOR REFRIGERANT PIPING; ROUTE PIPING IN SLEEVE EXCEPT FOR CONNECTIONS TO EXTERIOR UNITS.
4. ROUTE ALL INTERIOR EQUIPMENT CONDENSATE DRAINS TO NEAREST UTILITY SINK. PROVIDE CONDENSATE PUMPS

CONSTRUCTION KEYED NOTES:

- ① SINGLE THERMOSTAT TO CONTROL TWO UNIT HEATERS. PROVIDE RELAYS/ADAPTER KITS AS NECESSARY TO FACILITATE THIS CONTROL METHODOLOGY.
- ② MOUNT UNIT FROM ROOF STRUCTURE PER MANUFACTURER'S RECOMMENDATIONS.

UNAUTHORIZED ALTERATION OR ADDITION TO A PLAN BEARING A LICENSED PROFESSIONAL ENGINEER'S SEAL IS A VIOLATION OF SECTION 7209, SUB-DIVISION 2 OF THE N.Y. STATE EDUCATION LAW. FELLENER ENGINEERING, LLP CERTIFICATE OF AUTHORIZATION #: 0017795

FELLENER III
ENGINEERING LLP
www.felip.com

22 Mulberry St., Suite 2A, Middletown, NY 10940
t 845-343-1481 fx 845-343-4986

181 Church St., Suite 100, Poughkeepsie, NY 12601
t 845-454-9704 fx 855-320-8735

DESIGNED BY: RW DRAWN BY: WPB APPROVED BY: EDF FE PROJECT #: 23-369

DATE: September 17, 2024
Revisions:

H1.02

