NOTES:

- REFER TO CONTRACT DRAWING E-001 FOR ELECTRICAL LEGEND, ABBREVIATIONS, GENERAL NOTES, AND DRAWING LIST.
- REFER TO CONTRACT DRAWINGS F-701, F-702, AND F-703 FOR ELECTRICAL ONE-LINE DIAGRAMS.
- 3. REFER TO ARCHITECTURAL DRAWINGS FOR EXACT QUANTITY AND LOCATIONS OF RECEPTACLES AND DATA OUTLETS.
- 4. REFER TO AS/RS MANUFACTURER DRAWINGS FOR EXACT REQUIREMENTS OF AS/RS EQUIPMENT.

di Domenico + Partners LLP Architecture



ARCHITECT

3743 Crescent Street, 3rd Floor Long Island City, New York 11101 Tel 212-337-0400 Fax 212-337-3567

CIVIL PLANNING ENGINEER



JMC Planning Engineering Landscape Architecture & Land Surveying, PLLC 120 Bedford Road Armonk, New York 10504 Tel 914-273-5225 Fax 914-273-2102

MEP ENGINEER



Burns Engineering, PC. 1261 Broadway, Suite 708 New York, New York 10001 Tel 212-962-3503

 
STRUCTURAL ENGINEER





MANHATTAN BEER DISTRIBUTORS 20 DUNNIGAN DRIVE SUFFERN, NEW YORK

KEY PLAN



AREA OF WORK

REV	DESCRIPTION	DATE
	ISSUED FOR DOB SUBMISSION	09/10/2021
	ISSUED FOR BID	10/15/2021
	ISSUED FOR PROGRESS	01/18/2022
	ISSUED FOR BID	08/30/2022


DRAWN BY :	M.DIMATTIA
CHECKED BY:	B.NEMCHEK
APPROVED BY :	J.MIZRAHI
DATE :	09/10/21
SCALE:	AS NOTED

DRAWING TITLE:

ELECTRICAL POWER PLAN - 10 DUNNIGAN (NORTH)

DWG NUMBER :

E-208

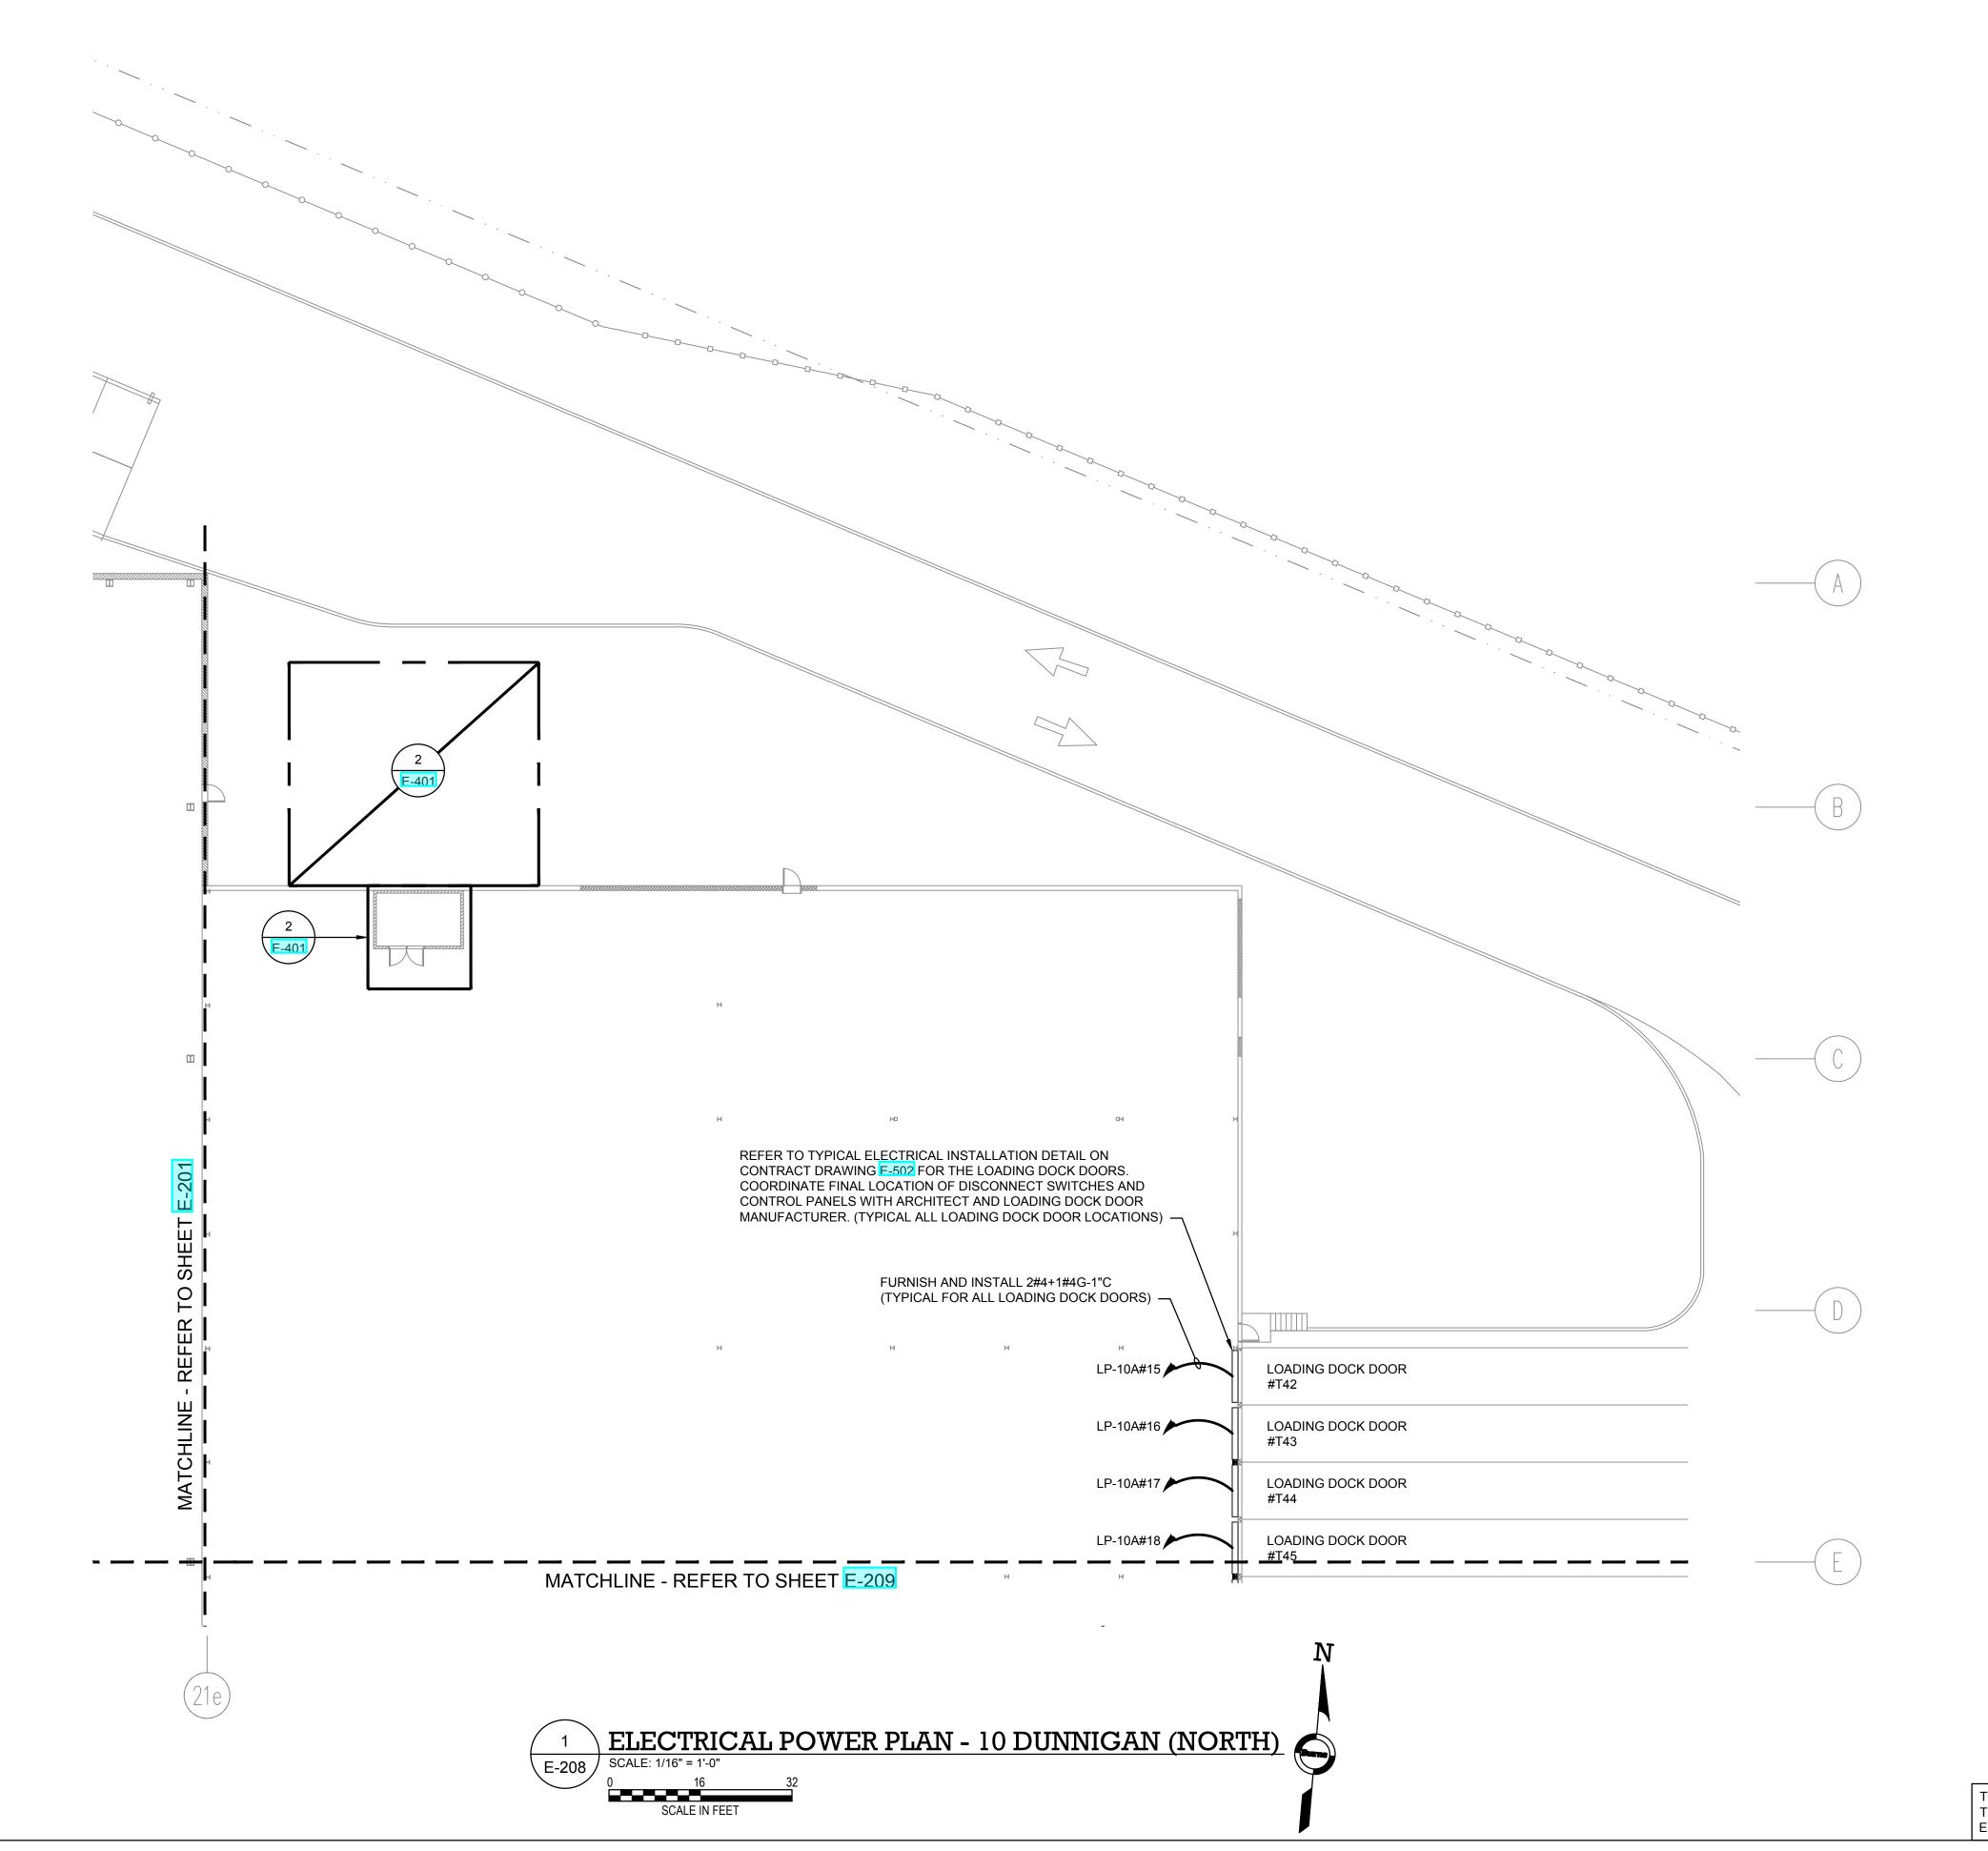

TO THE BEST KNOWLEDGE, BELIEF AND PROFESSIONAL JUDGEMENT, THESE PLANS AND SPECIFICATIONS ARE IN COMPLIANCE WITH THE 2020 ENERGY CONSERVATION CONSTRUCTION CODE OF NEW YORK STATE.