

## NOTES:

- 1. REFER TO CONTRACT DRAWING F-001 FOR ELECTRICAL LEGEND, ABBREVIATIONS, GENERAL NOTES, AND DRAWING LIST.
- 2. REFER TO CONTRACT DRAWINGS E-701, E-702, AND E-703 FOR ELECTRICAL ONE-LINE DIAGRAMS AND ELECTRICAL REQUIREMENTS OF EQUIPMENT.
- 3. REFER TO CONTRACT DRAWINGS E-905 AND E-906 FOR LOW VOLTAGE SWITCHBOARD SPECIFICATIONS.

ARCHITECT



Architecture

di Domenico + Partners LLP

Landscape Architecture Planning

3743 Crescent Street, 3rd Floor Long Island City, New York 11101 Tel 212-337-0400 Fax 212-337-3567

## CIVIL PLANNING ENGINEER



JMC Planning Engineering Landscape Architecture & Land Surveying, PLLC 120 Bedford Road Armonk, New York 10504 Tel 914-273-5225 Fax 914-273-2102

## MEP ENGINEER




Burns Engineering, PC. 1261 Broadway, Suite 708 New York, New York 10001 Tel 212-962-3503

STRUCTURAL ENGINEER



1385 Broadway, 20th FL

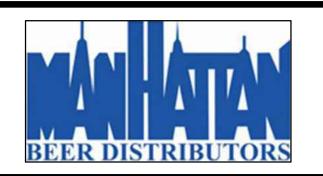

MANHATTAN BEER DISTRIBUTORS 20 DUNNIGAN DRIVE SUFFERN, NEW YORK

KEY PLAN

DESCRIPTION DATE ISSUED FOR DOB SUBMISSION 09/10/2021 ISSUED FOR BID 10/15/2021 ISSUED FOR PROGRESS 01/18/2022 ISSUED FOR BID 08/30/2022

DRAWN BY :	M.DIMATTIA
CHECKED BY:	B.NEMCHEK
APPROVED BY :	J.MIZRAHI
DATE :	09/10/21
SCALE:	AS NOTED

## DRAWING TITLE:

THESE PLANS AND SPECIFICATIONS ARE IN COMPLIANCE WITH THE 2020 ENERGY CONSERVATION CONSTRUCTION CODE OF NEW YORK STATE.

**ELECTRICAL ROOM PART** PLANS - INSTALLATIONS

DWG NUMBER:

E-402



FURNISH AND INSTALL PANELBOARD 'LP-10A'

L FURNISH AND INSTALL PANELBOARD 'DB'

 FURNISH AND INSTALL TRANSFORMER 'T-10'

SCALE IN FEET

- FURNISH AND INSTALL PANELBOARD 'PPH-10A'


- FURNISH AND INSTALL

HOUSEKEEPING PAD

LP-10A#5

LP-10A#5

(TYPICAL)

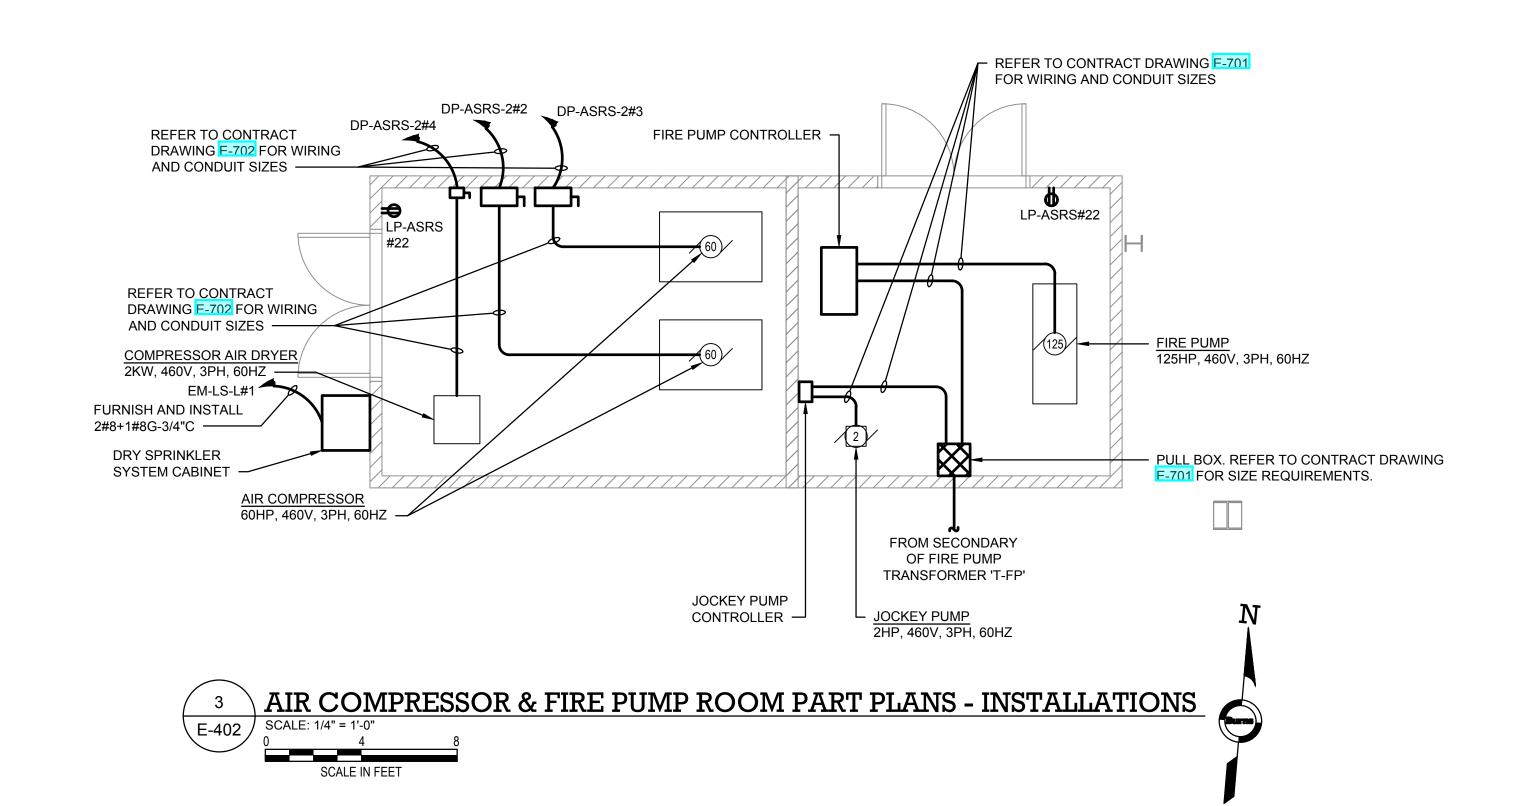

FURNISH AND INSTALL SWITCHBOARD

FURNISH AND INSTALL

FURNISH AND INSTALL SWITCHBOARD

'SWBD-N' MAIN BREAKER SECTION

2#10+1#10-3/4"C

'SWBD-N' DISTRIBUTION SECTION

- FURNISH AND INSTALL

- FURNISH AND INSTALL PANELBOARD 'EM-LP-C'

— FURNISH AND INSTALL PANELBOARD 'EM-QC-10'

DISTRIBUTION BOARD 'DP-10'

