



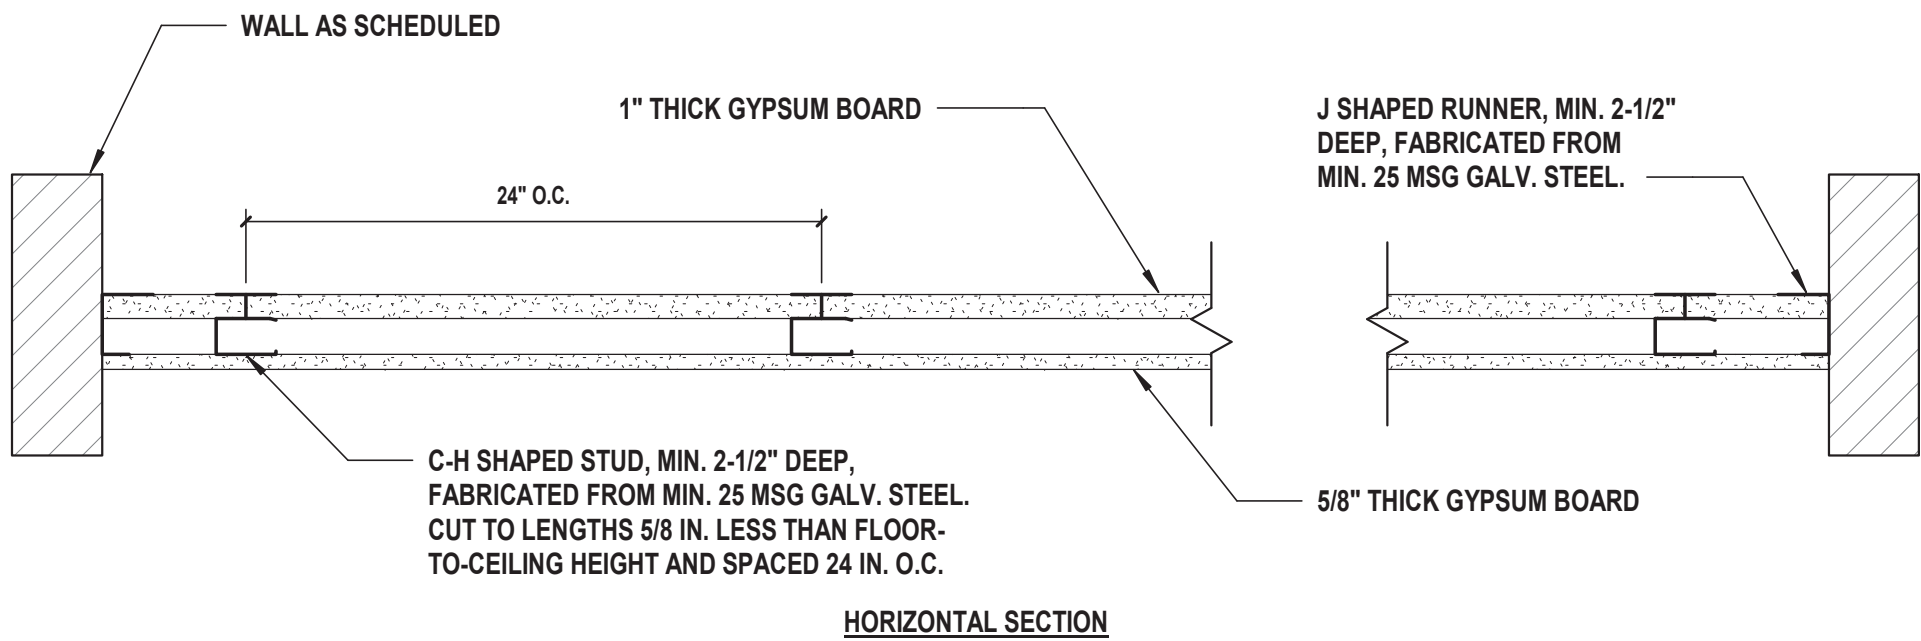


1 HOUR MIN. FIRE RATED CEILING UL: U417

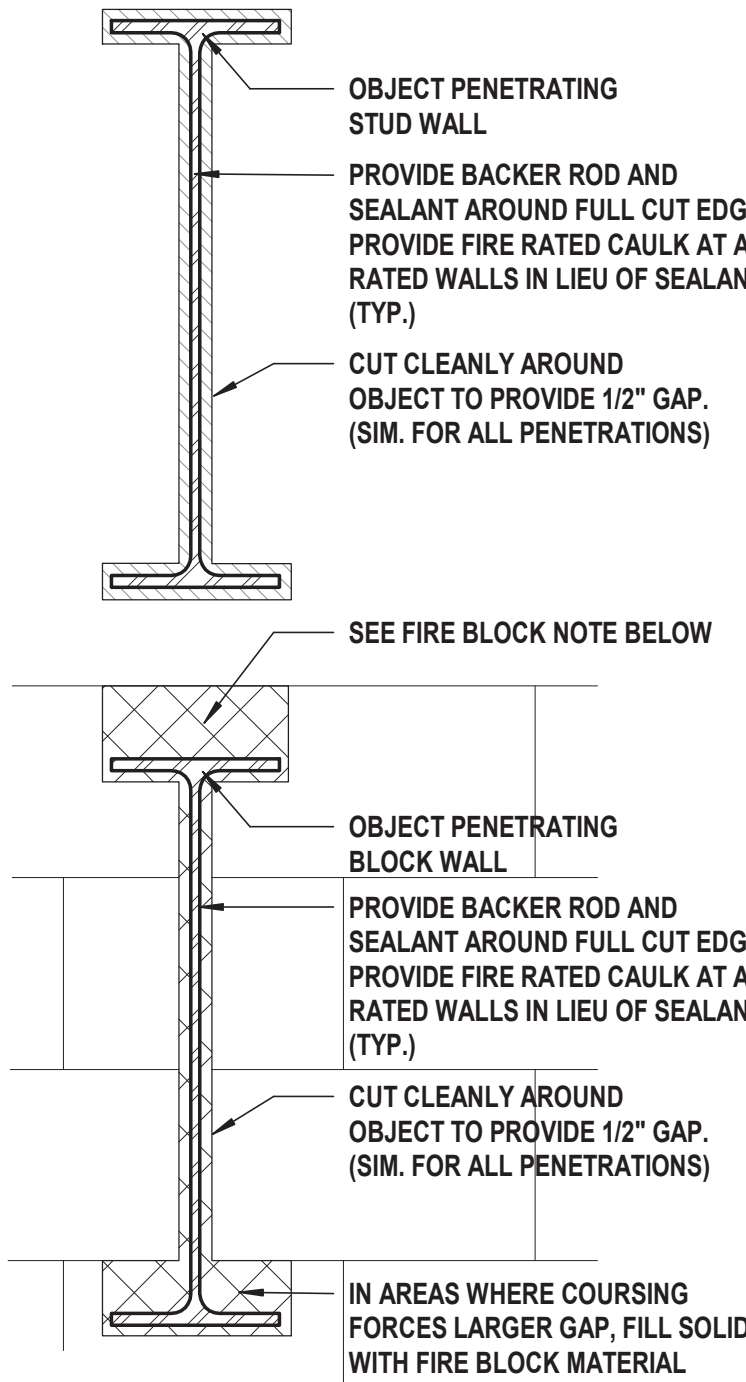


NOTE:
THESE DETAILS APPLY TO ALL PENETRATING ITEMS INCLUDING BEAMS, JOISTS, ANGLES, DUCTS, PIPES, CONDUIT, ETC. BEAMS ARE SHOWN FOR ILLUSTRATIVE PURPOSES ONLY.


TYPICAL HORIZONTAL PENETRATIONS AT WALLS

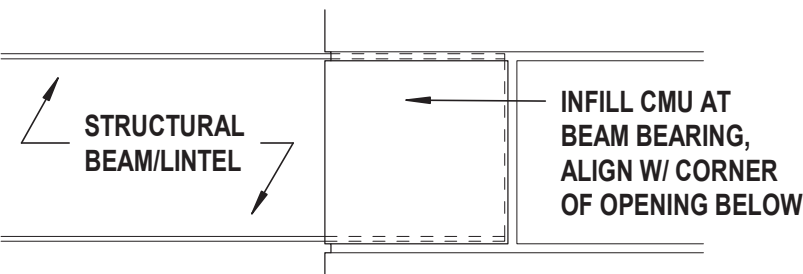


TYPICAL INFILL AT EXPOSED BEAM/ LINTEL BEARING

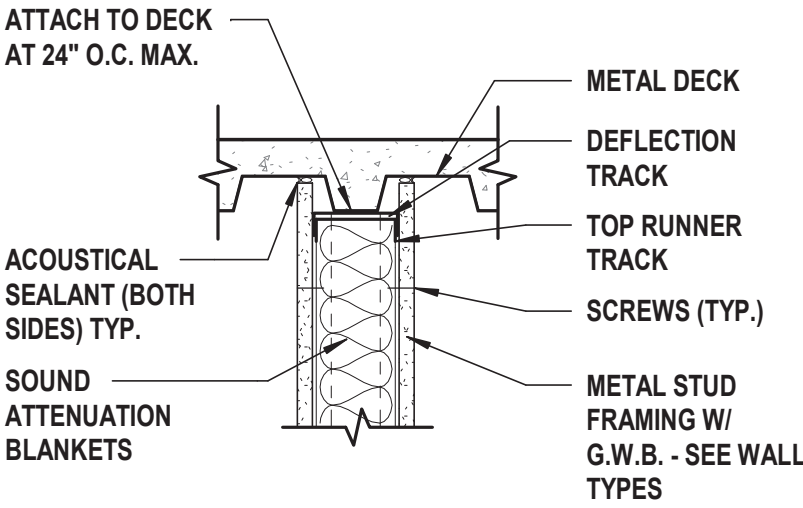

TYPICAL TOP OF WALL STUD FRAMING TO UNDERSIDE OF FLOOR OR ROOF DECKING WITH SOUND ATTENUATION BLANKETS

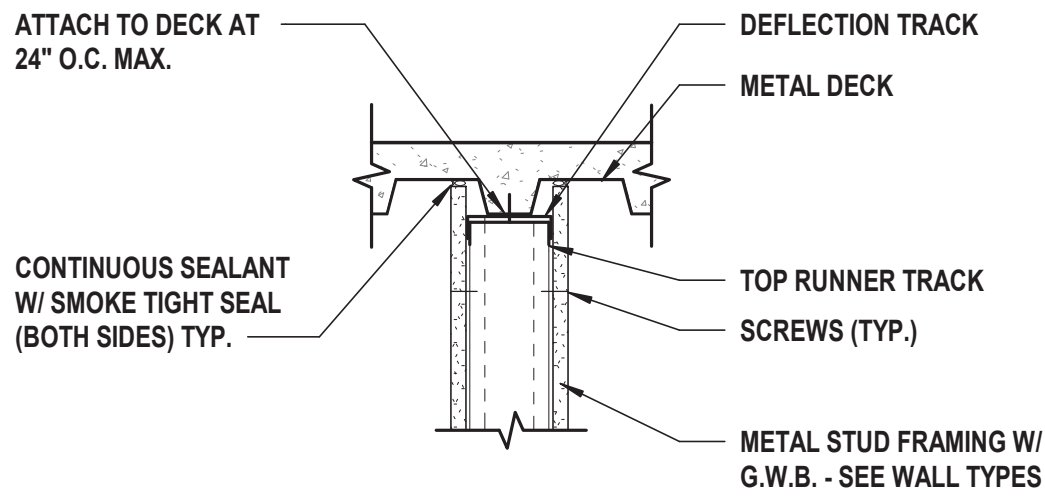


TYPICAL TOP OF STUD WALL FRAMING TO UNDERSIDE OF FLOOR OR ROOF DECKING @ NON-RATED PARTITIONS

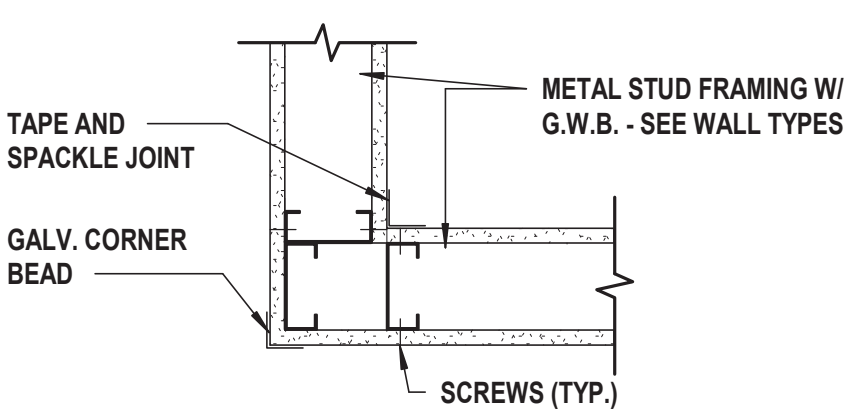


NOTE:
TYPICAL CORNER DETAIL OCCURS AT THE FOLLOWING LOCATIONS:
1. INTERSECTION AT NON-RATED PARTITIONS.
2. INTERSECTION AT RATED PARTITIONS.

TYPICAL STUD WALL CORNER DETAIL

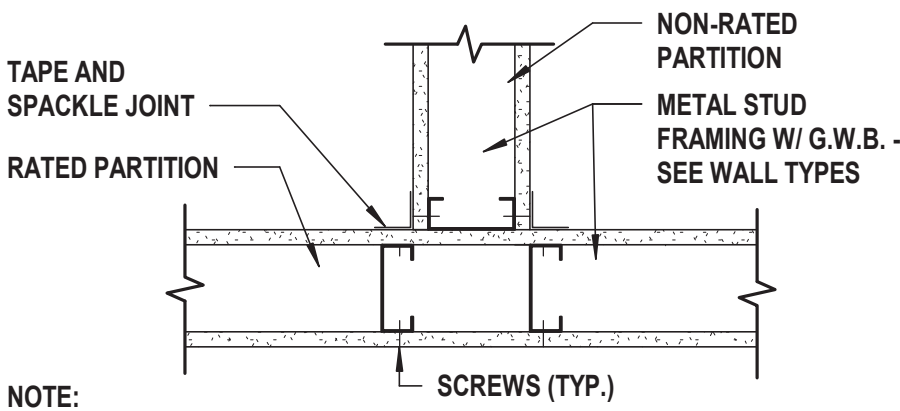


NOTE:
TYPICAL "T" INTERSECTION DETAIL OCCURS AT THE FOLLOWING LOCATIONS:
1. INTERSECTION AT A NON-RATED PARTITION AND A RATED PARTITION.


TYPICAL STUD WALL (NON-RATED INTERSECTION WITH A RATED PARTITION)

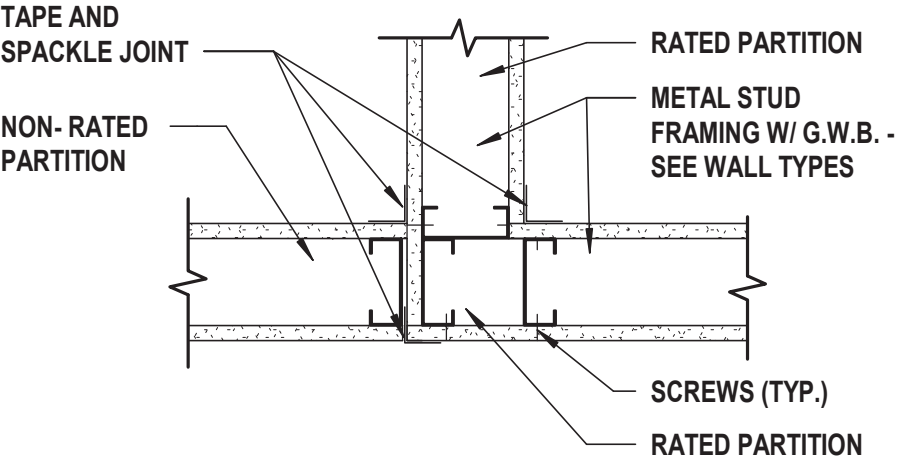


TYPICAL STUD WALL (RATED PARTITION CORNER INTERSECTION WITH A NON-RATED PARTITION)

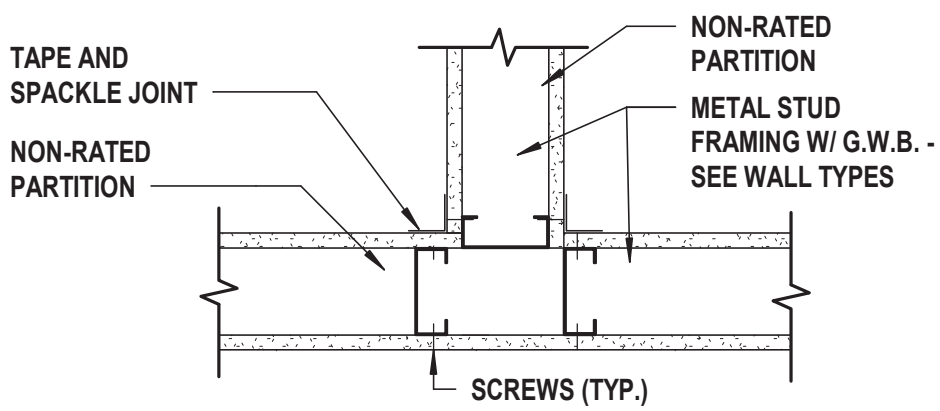


TYPICAL STUD WALL INTERSECTION @ NON-RATED PARTITIONS

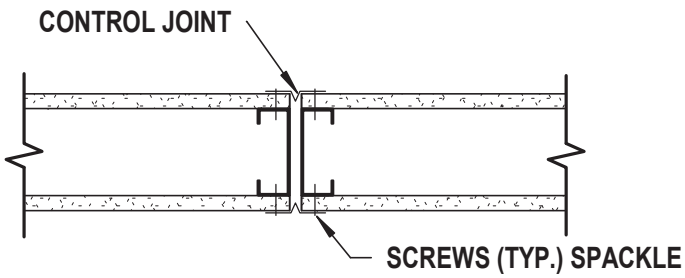

TYPICAL CONTROL JOINT @ STUD WALL

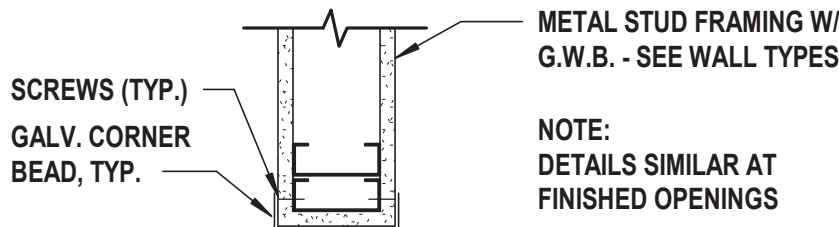



TYPICAL STUD WALL END CONDITION

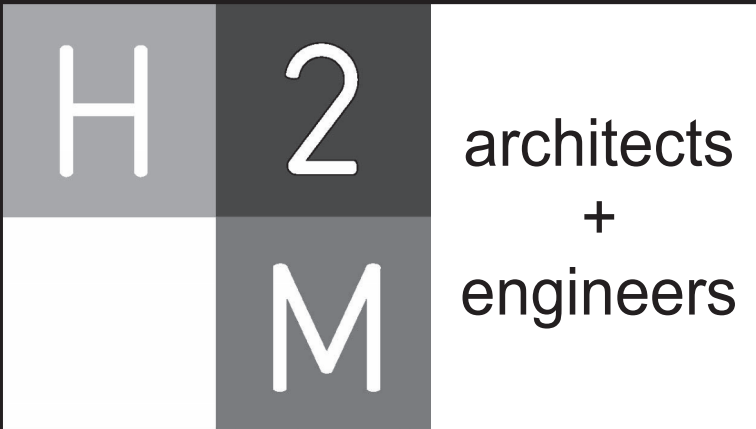

538 Broad Hollow Road, 4th Floor East
Melville, NY 11747
631.756.8000 • www.h2m.com
NY Architecture & Landscape Architecture: No Certificate Required
NY Engineering Certificate of Authorization No.: 0018178

CONSULTANTS:

MARK	DATE	DESCRIPTION

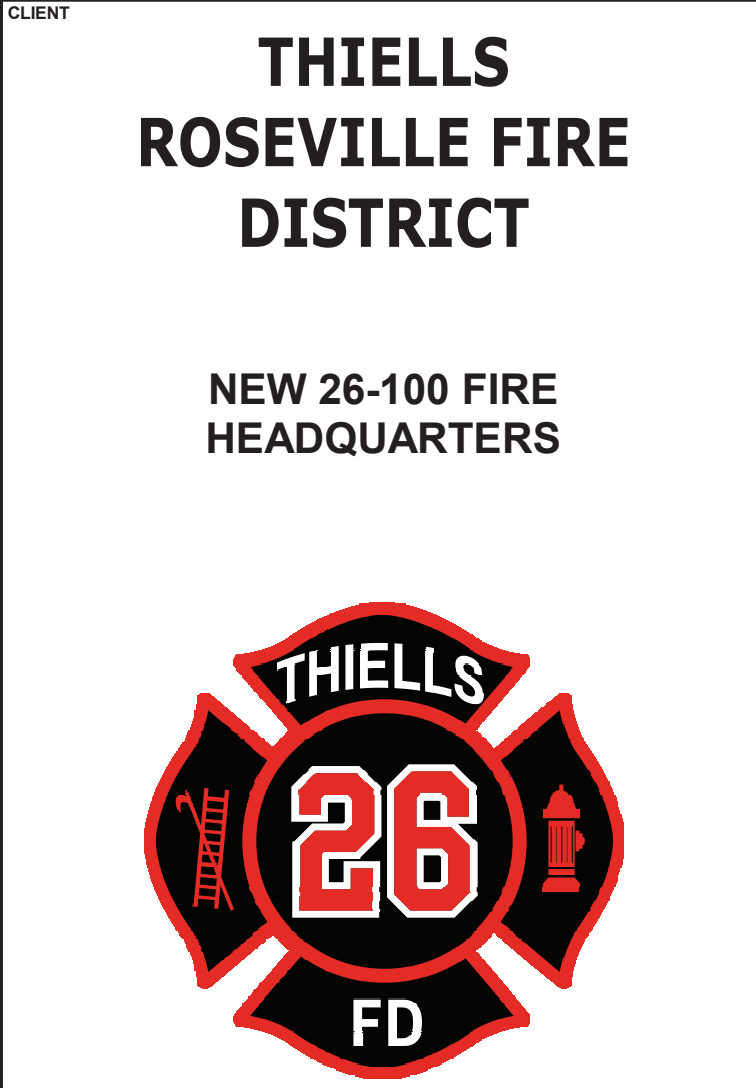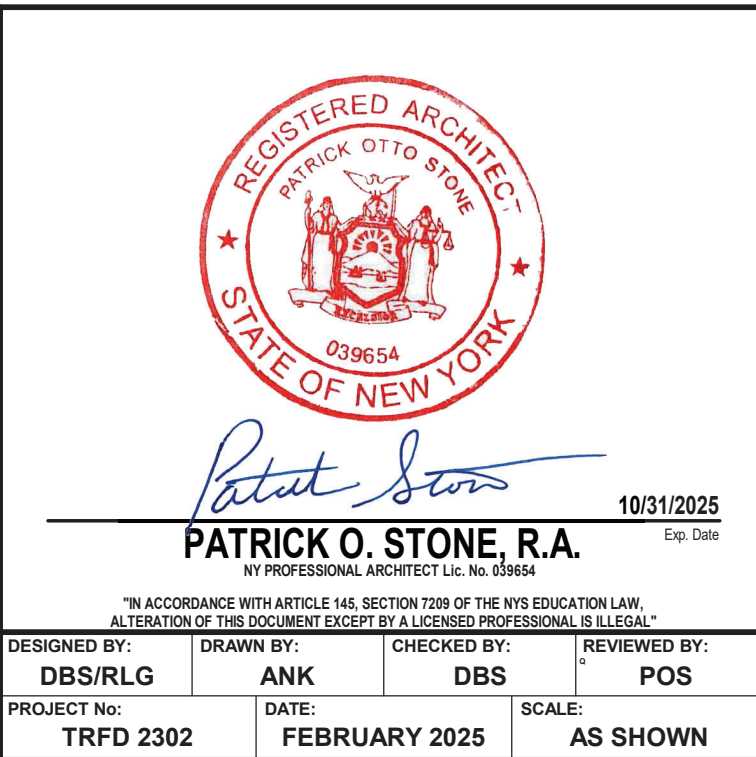


CONTRACT
CONTRACT G
GENERAL CONSTRUCTION

STATUS
FINAL BID DOCUMENT

SHEET TITLE
UL ASSEMBLIES

DRAWING No.
A 001.00

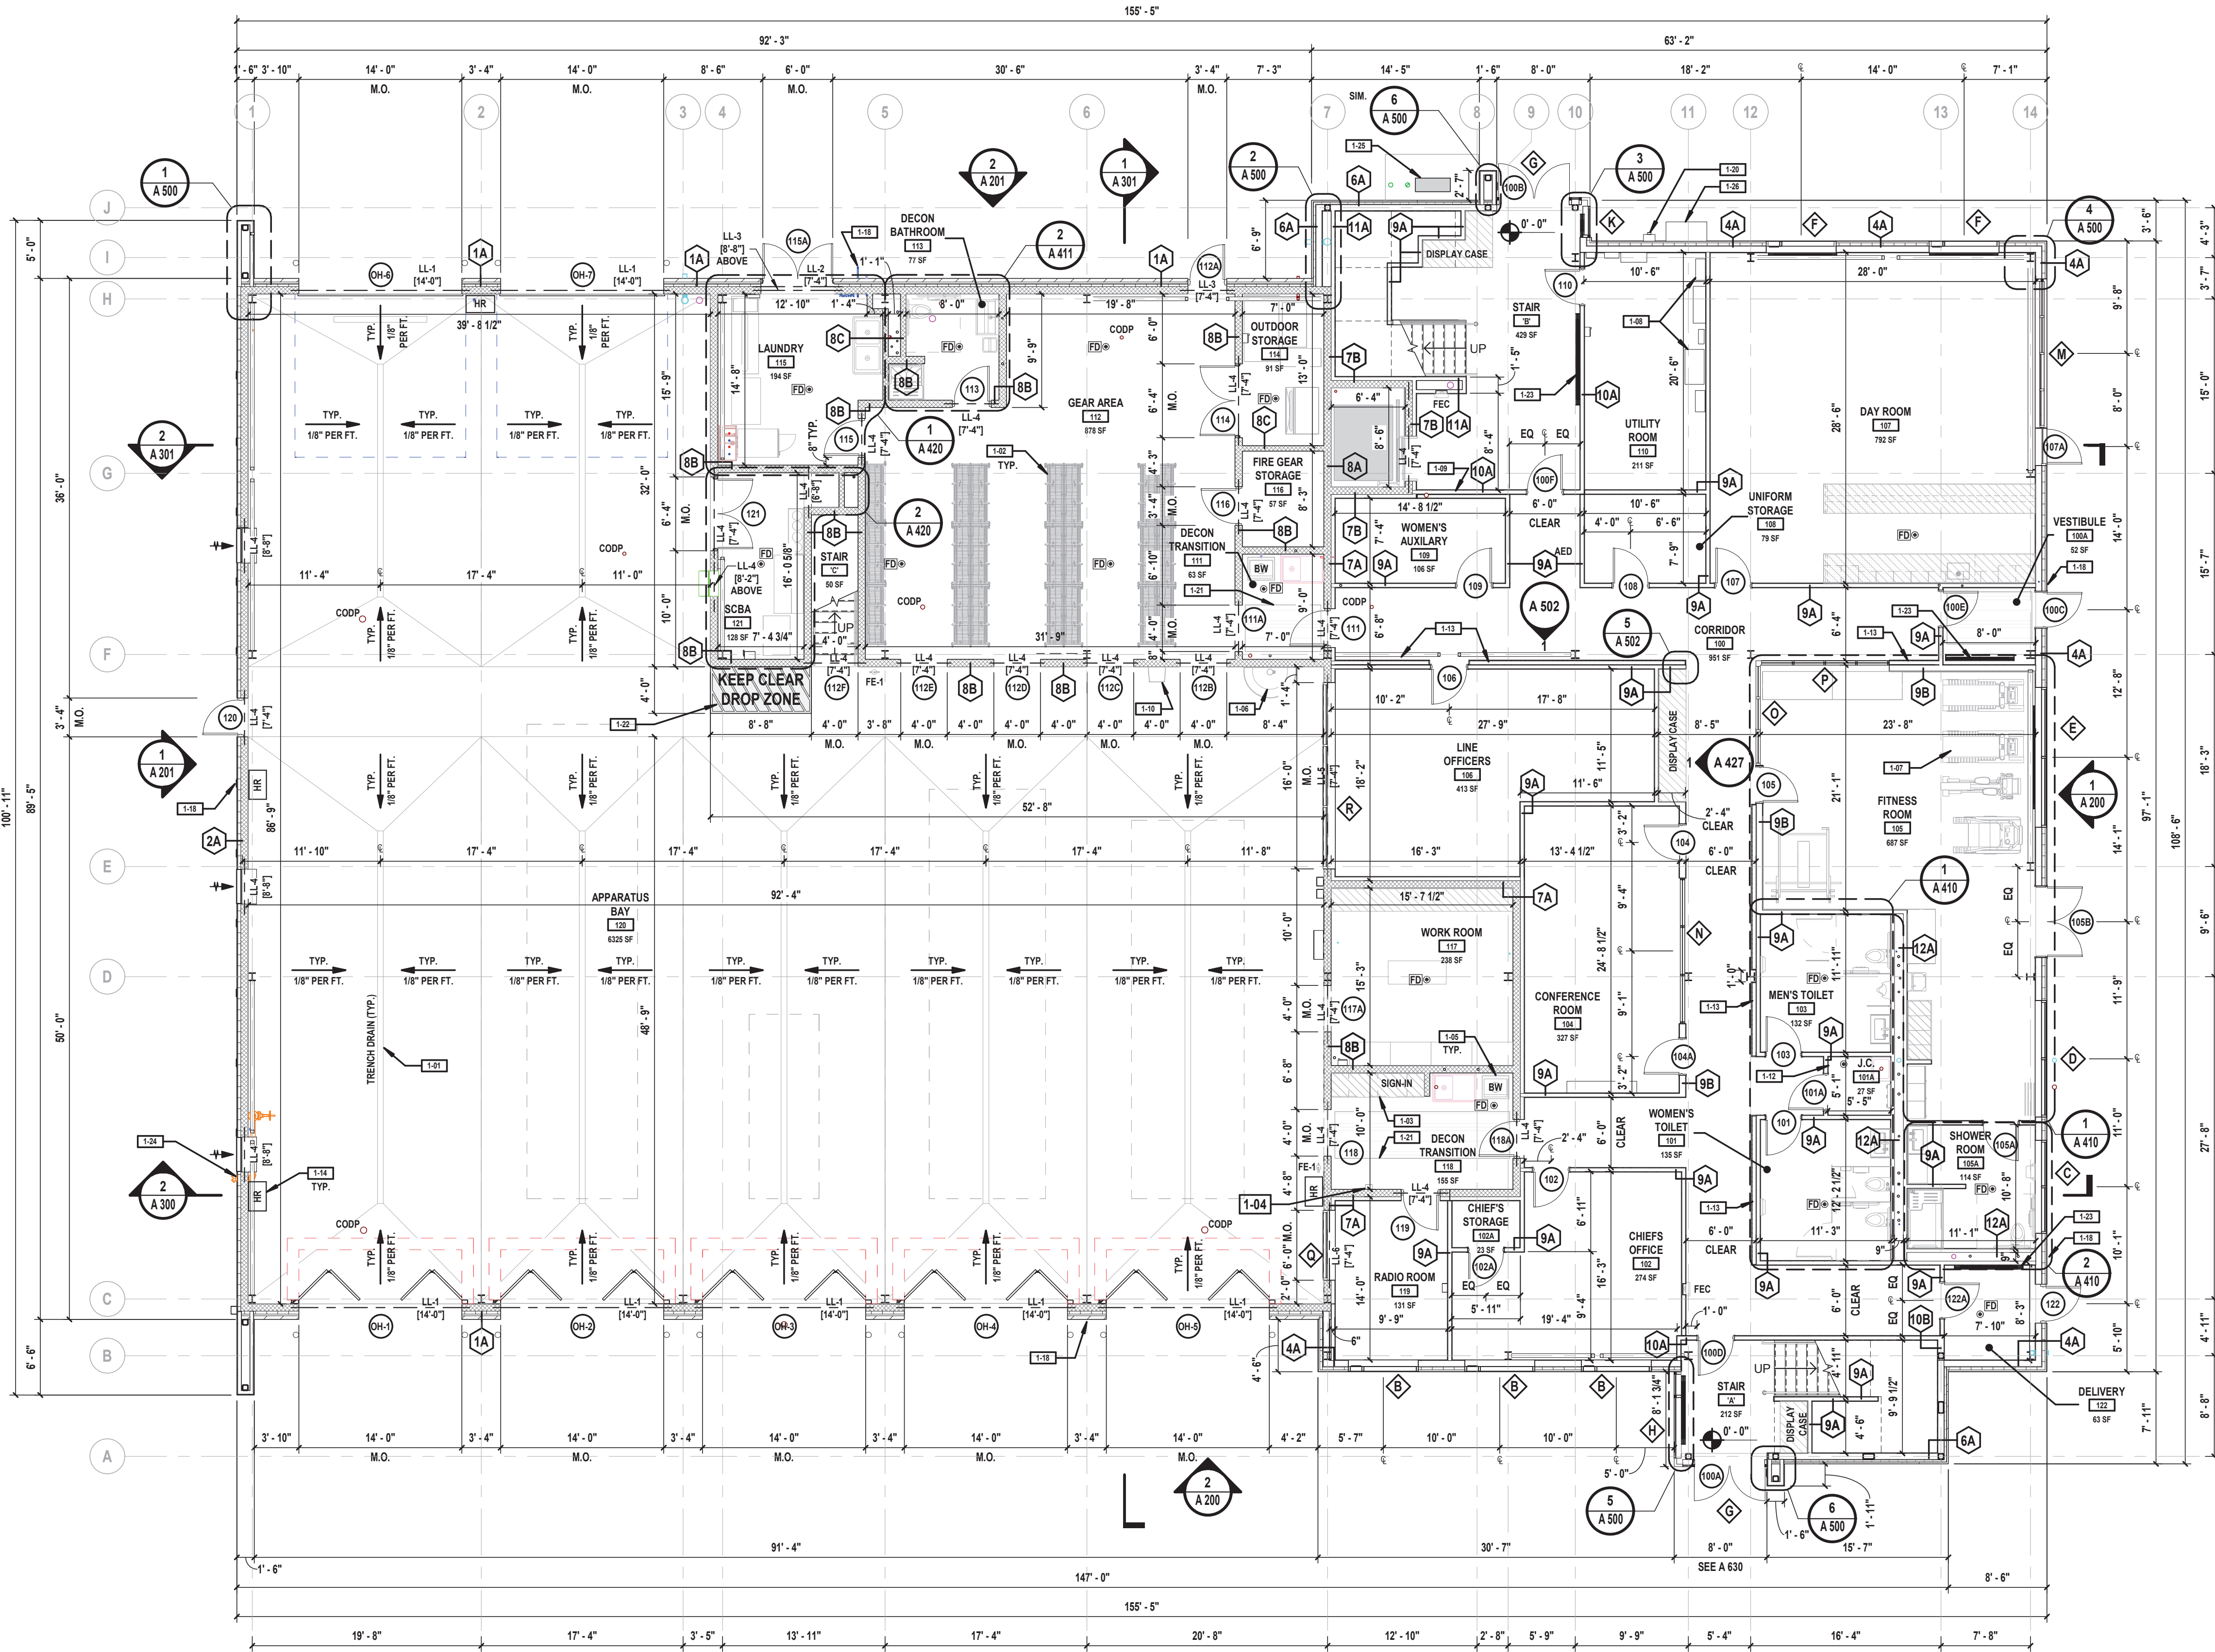

1 First Floor Plan
SCALE: 1/8" = 1'-0"

GENERAL FLOOR PLAN NOTES


- COORDINATE THE WORK INDICATED HERE WITH ALL CONTRACT DOCUMENTS AND SPECIFICATIONS.
- ALL DIMENSIONS ARE TO FACE OF ROUGH STUD OR CONCRETE MASONRY UNIT (STRUCTURE), UNLESS NOTED OTHERWISE.
- ALL DOORS IN STUD WALLS SHALL BE EITHER CENTERED ON WALLS OR 4" FROM WALL TO ROUGH JAMB, UNLESS NOTED OTHERWISE.
- PROVIDE SADDLES WHERE INDICATED AT ROOM TRANSITIONS AS NOTED IN DOOR SCHEDULE. SADDLES TO BE FULL WIDTH OF OPENING. (SEE DOOR SADDLE DETAILS FOR ADDITIONAL INFORMATION).
- ALL PAINTING SHALL BE PERFORMED IN ACCORDANCE WITH REQUIREMENTS CONTAINED IN SECTION 099000 OF PROJECT MANUAL.
- REFER TO A 400 SERIES ENLARGED FLOOR PLANS, DETAILS, EQUIPMENT SCHEDULES AND ALL OTHER CONTRACT DOCUMENTS AND SPECIFICATIONS FOR ADDITIONAL FRAMING INFORMATION.
- FOR ALL LINTELS DENOTED AS LL-#, SEE LINTEL SCHEDULE AND 'S' DRAWINGS FOR ADDITIONAL INFORMATION. ALL ELEVATIONS DENOTED [X'-X"] ARE TAKEN FROM ABOVE FINISH FLOOR (A.F.F.).
- FOR DOORS DENOTED , REFER TO DOOR SCHEDULE FOR ADDITIONAL INFORMATION.
- FOR WINDOWS DENOTED , REFER TO WINDOW SCHEDULE FOR ADDITIONAL INFORMATION.
- CONTRACT 'G' IS REQUIRED TO COORDINATE WITH ALL OTHER CONTRACTS AND ACCOMMODATE CONSTRUCTION TO ACCEPT ALL PIPING, CONDUITS, EQUIPMENT, ETC., EITHER SPECIFIED OR DETAILED TO BE RECESSED OR CONCEALED IN WALLS AS REQUIRED.
- ALL EXPOSED CORNERS OF CONCRETE MASONRY UNIT WALL CONSTRUCTION SHALL HAVE BULLNOSE EDGE. SEE DETAILS ON A 500 SERIES DRAWINGS FOR ADDITIONAL INFORMATION.

FLOOR PLAN LEGEND

	NEW FLOOR DRAIN, PITCH FLOOR FOR POSITIVE DRAINAGE - COORDINATE WITH CONTRACT 'P'
	NEW FLOOR CLEAN OUT - COORDINATE WITH CONTRACT 'P'
	RECESSED FIRE EXTINGUISHER CABINET, REFER TO SPECIFICATIONS
	SURFACE MOUNTED FIRE EXTINGUISHER, REFER TO SPECIFICATIONS

FIRST FLOOR CONSTRUCTION KEYNOTE LEGEND


KEYNOTE	DESCRIPTION
1-01	RECESSED TRENCH DRAIN WITH CAST IRON GRATING. TRENCH DRAINAGE SHALL BE PROVIDED BY CONTRACT 'P' AND INSTALLED BY CONTRACT 'G' WHEN APPARATUS BAY SLAB ON GRADE IS INSTALLED. SEE DETAIL 3/S S10.
1-02	GEAR LOCKERS PROVIDED BY OWNER, INSTALLED BY CONTRACT 'G'.
1-03	POWDER COATED STEEL CASEWORK BY CONTRACT 'G', SEE INTERIOR ELEVATIONS FOR ADD'L INFO.
1-04	SURFACE MOUNTED HAND SANITIZER PROVIDED AND INSTALLED BY CONTRACT 'G', FINAL LOCATIONS TO BE DETERMINED IN FIELD WITH OWNER/ARCHITECT.
1-05	BOOT WASH STATION. PROVIDED AND INSTALLED BY CONTRACT 'G'.
1-06	WASHFOUNTAIN PROVIDED AND INSTALLED BY CONTRACT 'P', REFER TO 'P' DRAWINGS.
1-07	FITNESS EQUIPMENT PROVIDED BY OWNER. COORDINATE WITH OWNER VENDOR FOR FINAL INSTALLATION.
1-08	ELECTRICAL SERVICE CABINETS, COORDINATE WITH CONTRACT 'E' FOR INSTALLATION.
1-09	CONTRACTOR TO CONSTRUCT 1-HR RATED WALL (10A) PRIOR TO CONSTRUCTION OF 7B FURRED WALL. 1-HR RATING INTEGRITY TO BE MAINTAINED FOR STAIR ENCLOSURE.
1-10	EMERGENCY EYE WASH STATION PROVIDED AND INSTALLED BY CONTRACT 'G'.
1-11	ALUMINUM FRAMED TACKBOARD PROVIDED BY CONTRACT 'G', SEE INTERIOR ELEVATION FOR SIZE.
1-12	ALL WALLS IN J.C. TO BE FINISHED WITH FRP PROTECTION PANELS, 54" HIGH. TYP. AT ALL J.C., REFER TO FINISH SCHEDULE.
1-13	INTERIOR WALL PANEL WITH LIGHT COVE. REFER TO DETAILS FOR ADDITIONAL INFORMATION. COORDINATE LIGHT COVE WITH CONTRACT 'E'.
1-14	HOSE REEL PROVIDED AND INSTALLED BY CONTRACT 'P'. REFER TO 'P' DRAWINGS FOR ADDITIONAL INFORMATION.
1-16	ELECTRICAL PANEL BY CONTRACT 'E', REFER TO 'E' DRAWINGS.
1-17	INCOMING GAS SERVICE, CONTRACT 'G' TO COORDINATE INSTALLATION AND SEQUENCING WITH CONTRACT 'P'.
1-18	FROST PROOF HOSE BIB, COORDINATE WITH CONTRACT 'P'.
1-20	ELECTRICAL METER AND INCOMING SERVICE, COORDINATE FINAL INSTALLATION AND SEQUENCING WITH CONTRACT 'E'.
1-21	RECESSED WALK OFF MAT PROVIDED BY CONTRACT 'G'.
1-22	PROVIDE STRIPED AREA WITH CHEVRON CROSS HATCH IN SAFETY YELLOW PAINT DIRECTLY BELOW TRAINING AREA.
1-23	ELECTRIC BASEBOARD HEATER, COORDINATE INSTALLATION WITH CONTRACT 'M'.
1-24	FIRE DEPARTMENT CONNECTION. REFER TO FIRE PROTECTION DRAWINGS.
1-25	GAS METER RIG ON POURED CONCRETE PAD BY CONTRACT 'P'.
1-26	CURRENT TRANSFORMER (CT) CABINET BY CONTRACT 'E'.

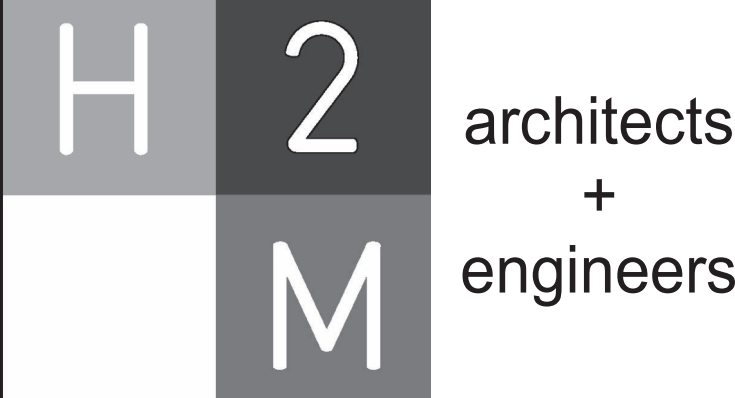

538 Broad Hollow Road, 4th Floor East
Melville, NY 11747
631.756.8000 • www.h2m.com
NY Architecture & Landscape Architecture: No Certificate Required
NY Engineering Certificate of Authorization No.: 0018178

CONSULTANTS:

MARK	DATE	DESCRIPTION

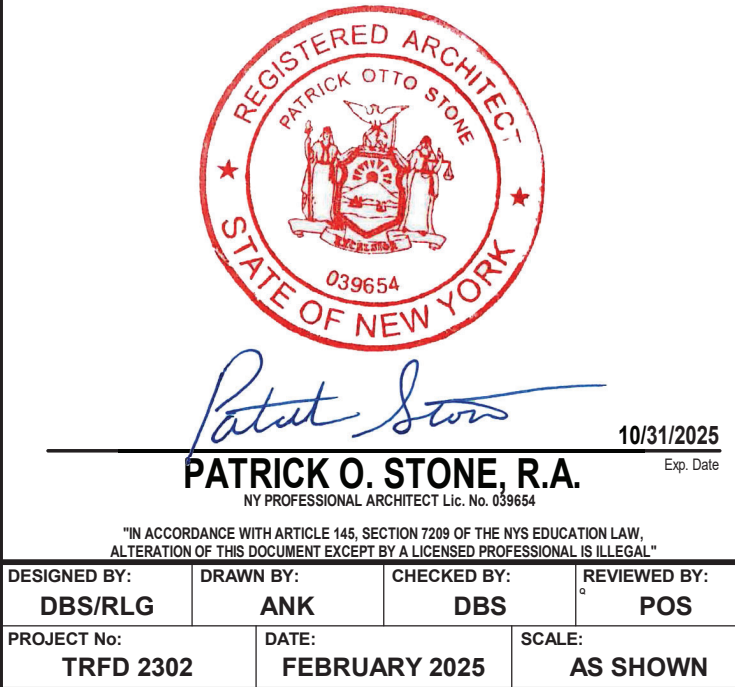

CLIENT

THIELLS ROSEVILLE FIRE DISTRICT

NEW 26-100 FIRE HEADQUARTERS



65 W RAMAPO ROAD
GARNERVILLE, NY 10923

CONTRACT

CONTRACT G GENERAL CONSTRUCTION

STATUS


FINAL BID DOCUMENT

SHEET TITLE

FLOOR PLAN - FIRST FLOOR

DRAWING No.

A 101.00

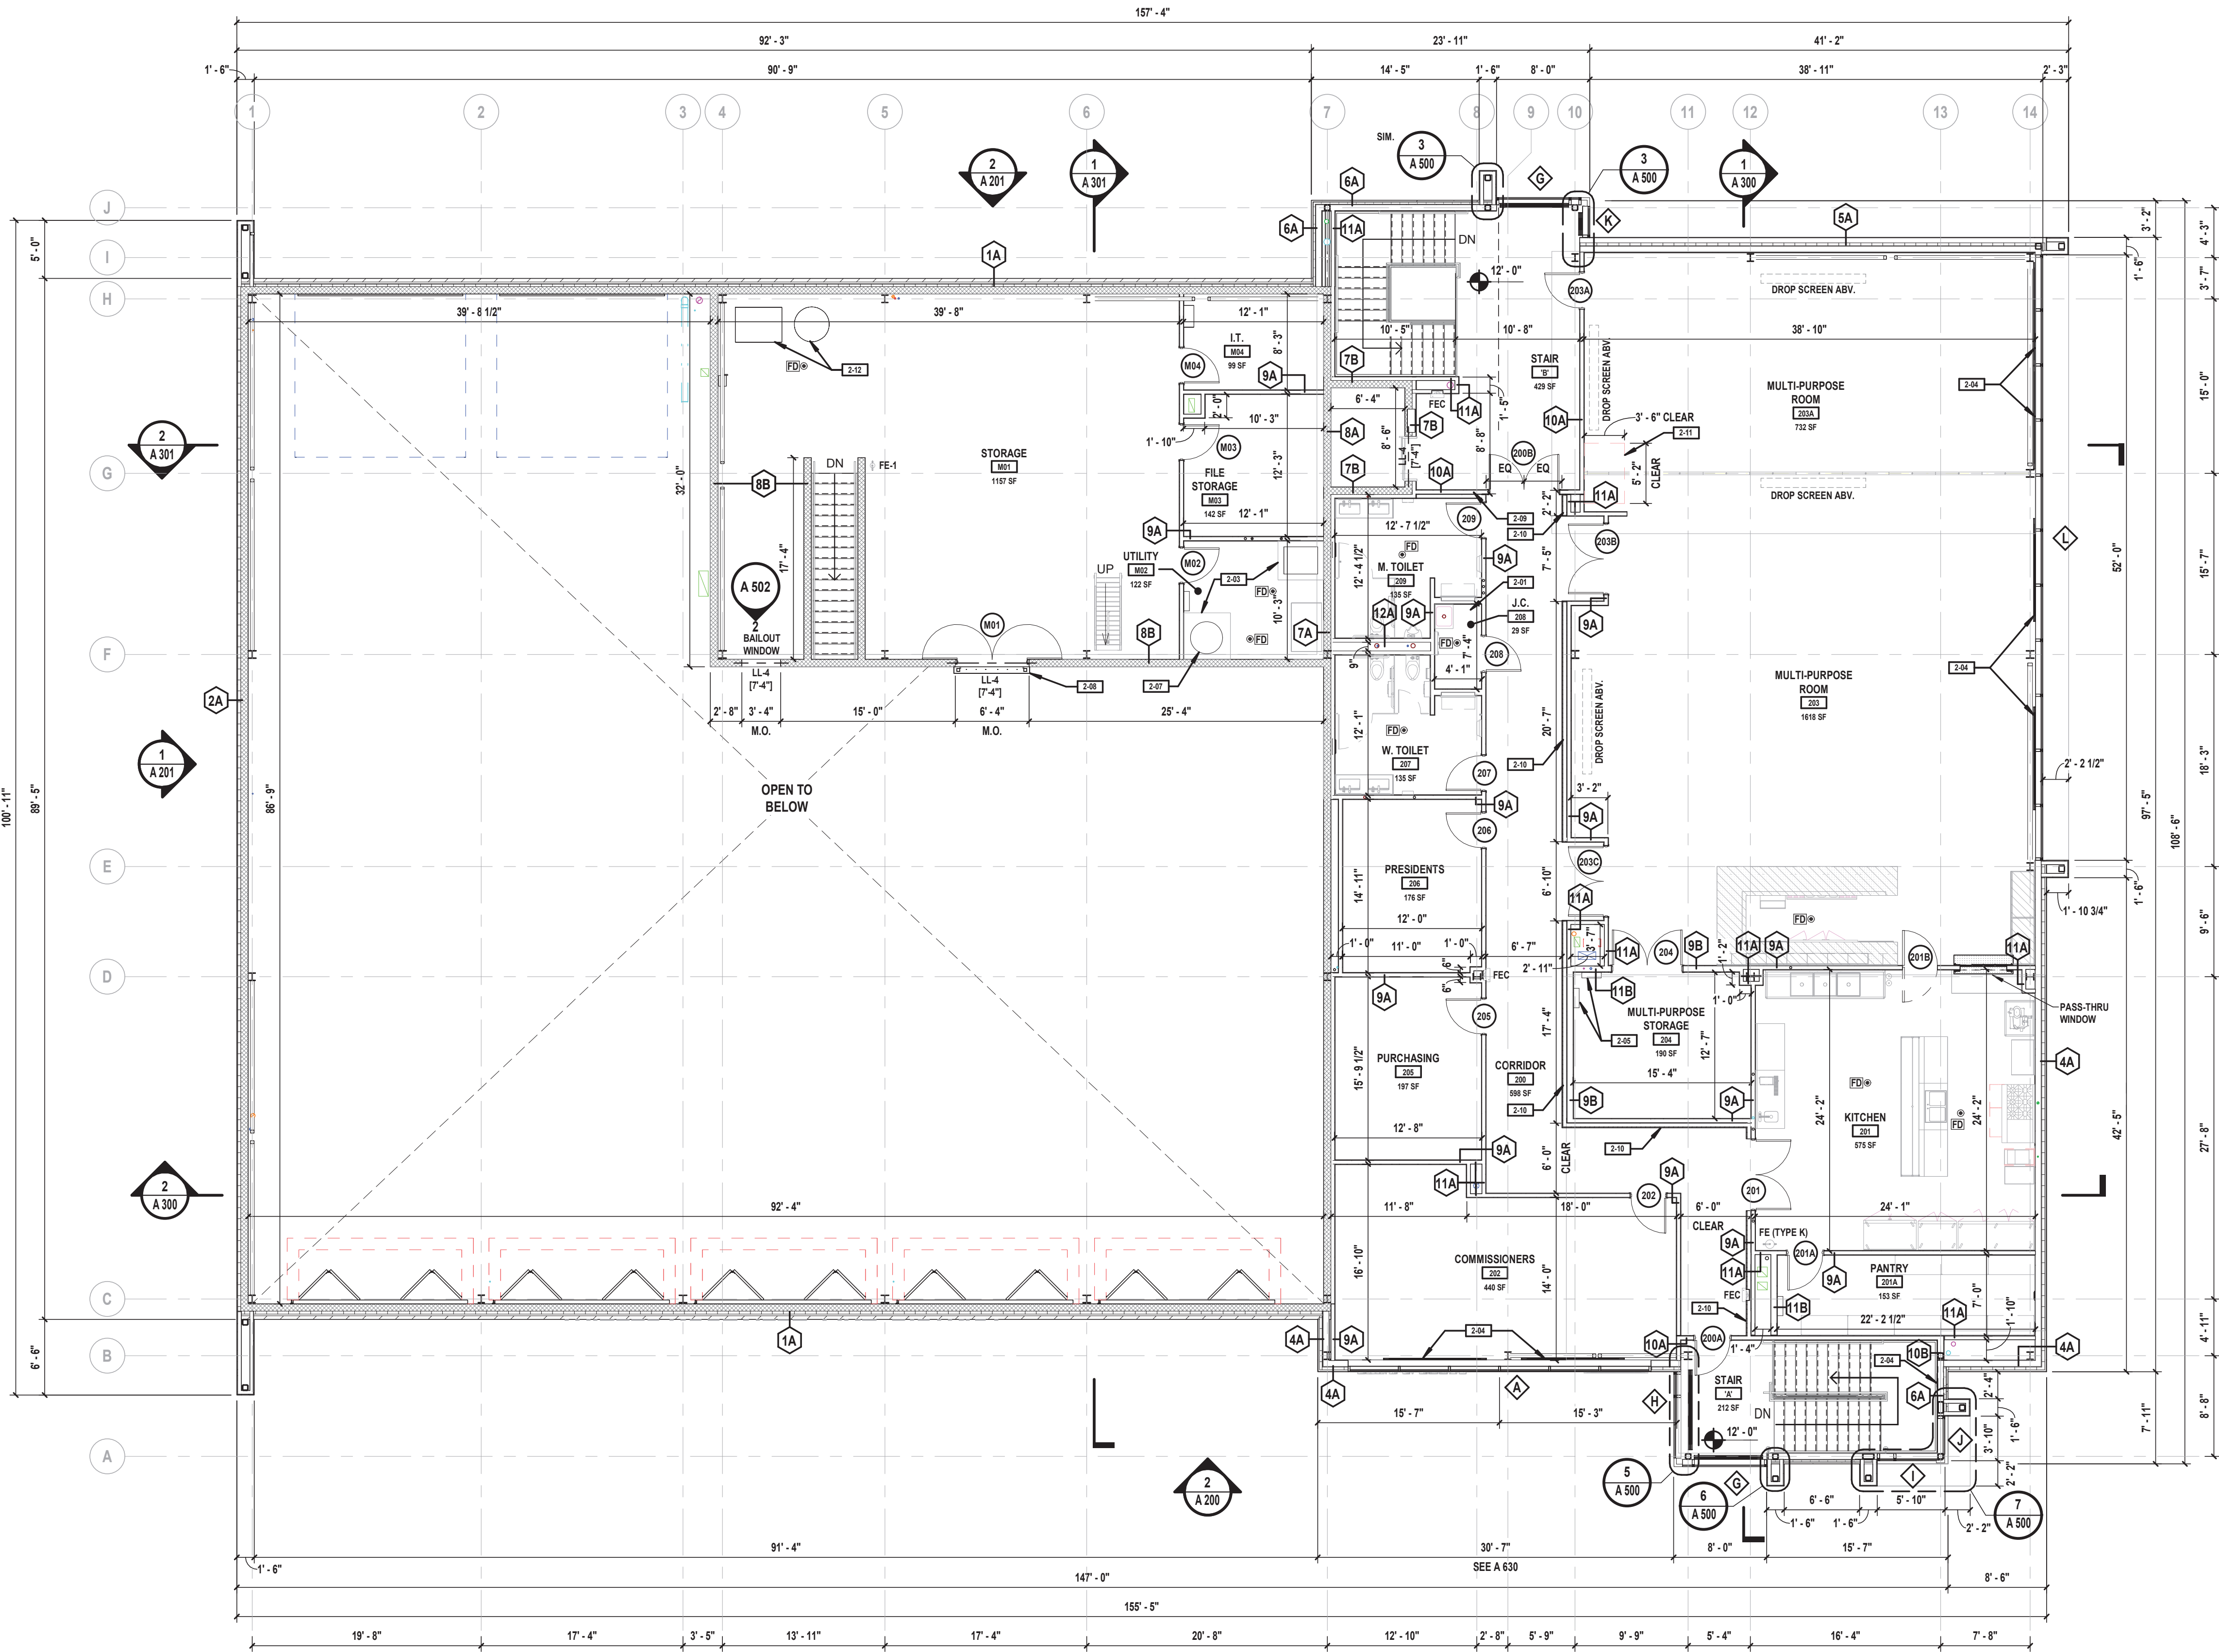

1 Second Floor Plan
SCALE: 1/8" = 1'-0"

GENERAL FLOOR PLAN NOTES


- COORDINATE THE WORK INDICATED HERE WITH ALL CONTRACT DOCUMENTS AND SPECIFICATIONS.
- ALL DIMENSIONS ARE TO FACE OF ROUGH STUD OR CONCRETE MASONRY UNIT (STRUCTURE), UNLESS NOTED OTHERWISE.
- ALL DOORS IN STUD WALLS SHALL BE EITHER CENTERED ON WALLS OR 4" FROM WALL TO ROUGH JAMB, UNLESS NOTED OTHERWISE.
- PROVIDE SADDLES WHERE INDICATED AT ROOM TRANSITIONS AS NOTED IN DOOR SCHEDULE. SADDLES TO BE FULL WIDTH OF OPENING. (SEE DOOR SADDLE DETAILS FOR ADDITIONAL INFORMATION).
- ALL PAINTING SHALL BE PERFORMED IN ACCORDANCE WITH REQUIREMENTS CONTAINED IN SECTION 099000 OF PROJECT MANUAL.
- REFER TO A 400 SERIES ENLARGED FLOOR PLANS, DETAILS, EQUIPMENT SCHEDULES AND ALL OTHER CONTRACT DOCUMENTS AND SPECIFICATIONS FOR ADDITIONAL FRAMING INFORMATION.
- FOR ALL LINTELS DENOTED AS LL-#, SEE LINTEL SCHEDULE AND 'S' DRAWINGS FOR ADDITIONAL INFORMATION. ALL ELEVATIONS DENOTED [X'-X"] ARE TAKEN FROM ABOVE FINISH FLOOR (A.F.F.).
- FOR DOORS DENOTED , REFER TO DOOR SCHEDULE FOR ADDITIONAL INFORMATION.
- FOR WINDOWS DENOTED , REFER TO WINDOW SCHEDULE FOR ADDITIONAL INFORMATION.
- CONTRACT 'G' IS REQUIRED TO COORDINATE WITH ALL OTHER CONTRACTS AND ACCOMMODATE CONSTRUCTION TO ACCEPT ALL PIPING, CONDUITS, EQUIPMENT, ETC., EITHER SPECIFIED OR DETAILED TO BE RECESSED OR CONCEALED IN WALLS AS REQUIRED.
- ALL EXPOSED CORNERS OF CONCRETE MASONRY UNIT WALL CONSTRUCTION SHALL HAVE BULLNOSE EDGE. SEE DETAILS ON A 500 SERIES DRAWINGS FOR ADDITIONAL INFORMATION.

FLOOR PLAN LEGEND

 	NEW FLOOR DRAIN, PITCH FLOOR FOR POSITIVE DRAINAGE - COORDINATE WITH CONTRACT 'P'
CODE 	NEW FLOOR CLEAN OUT - COORDINATE WITH CONTRACT 'P'
	RECESSED FIRE EXTINGUISHER CABINET, REFER TO SPECIFICATIONS
	SURFACE MOUNTED FIRE EXTINGUISHER, REFER TO SPECIFICATIONS

SECOND FLOOR CONSTRUCTION KEYNOTE LEGEND


KEYNOTE	DESCRIPTION
2-01	ALL WALLS IN J.C. TO BE FINISHED WITH FRP PROTECTION PANELS, 54" HIGH. TYP. AT ALL J.C., REFER TO FINISH SCHEDULE.
2-03	CONCRETE HOUSEKEEPING PAD, PROVIDED AND INSTALLED BY CONTRACT 'P'.
2-04	ELECTRIC HEATER, COORDINATE WITH CONTRACT 'W'.
2-05	ELECTRICAL PANEL PROVIDED AND INSTALLED BY CONTRACT 'E', REFER TO ELECTRICAL DRAWINGS.
2-07	HOT WATER HEATER PROVIDED AND INSTALLED BY CONTRACT 'P', COORDINATE WITH CONTRACT 'P'.
2-08	SAFETY GATE, REFER TO DOOR DETAILS FOR ADDITIONAL INFORMATION.
2-09	CONTRACTOR TO CONSTRUCT 1-HR RATED WALL (10A) PRIOR TO CONSTRUCTION OF 7B FURRED WALL. 1-HR RATING INTEGRITY TO BE MAINTAINED FOR STAIR ENCLOSURE.
2-10	INTERIOR WALL PANEL WITH LIGHT COVE, REFER TO DETAILS FOR ADDITIONAL INFORMATION. COORDINATE LIGHT COVE WITH CONTRACT 'E'.
2-11	STACK OF OPERABLE PARTITION WHEN IN THE OPEN POSITION. PROVIDE NO WALL BASE WHERE PARTITION JAMB ABUTS WALL CONSTRUCTION.
2-12	UNDERCARRIAGE SPRAY SYSTEM TANK AND PUMP BY CONTRACT 'P', REFER TO PLUMBING DRAWINGS.

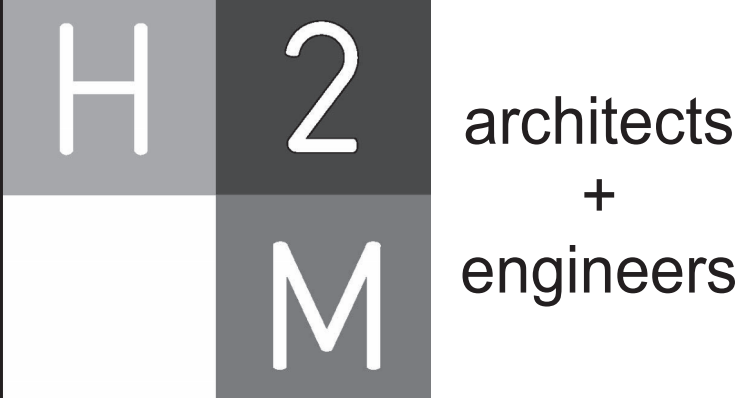

538 Broad Hollow Road, 4th Floor East
Melville, NY 11747
631.756.8000 • www.h2m.com
NY Architecture & Landscape Architecture: No Certificate Required
NY Engineering Certificate of Authorization No.: 0018178

CONSULTANTS:

MARK	DATE	DESCRIPTION

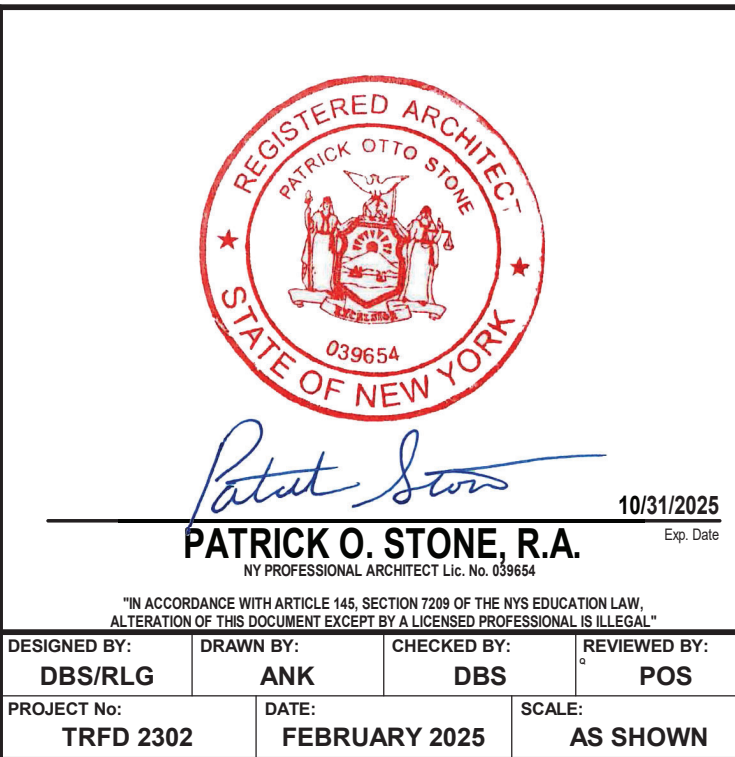

CLIENT

**THIELLS
ROSEVILLE FIRE
DISTRICT**

**NEW 26-100 FIRE
HEADQUARTERS**



**65 W RAMAPO ROAD
GARNERVILLE, NY 10923**

CONTRACT

**CONTRACT G
GENERAL CONSTRUCTION**

STATUS


FINAL BID DOCUMENT

SHEET TITLE

FLOOR PLAN - SECOND FLOOR

DRAWING No.

A 102.00

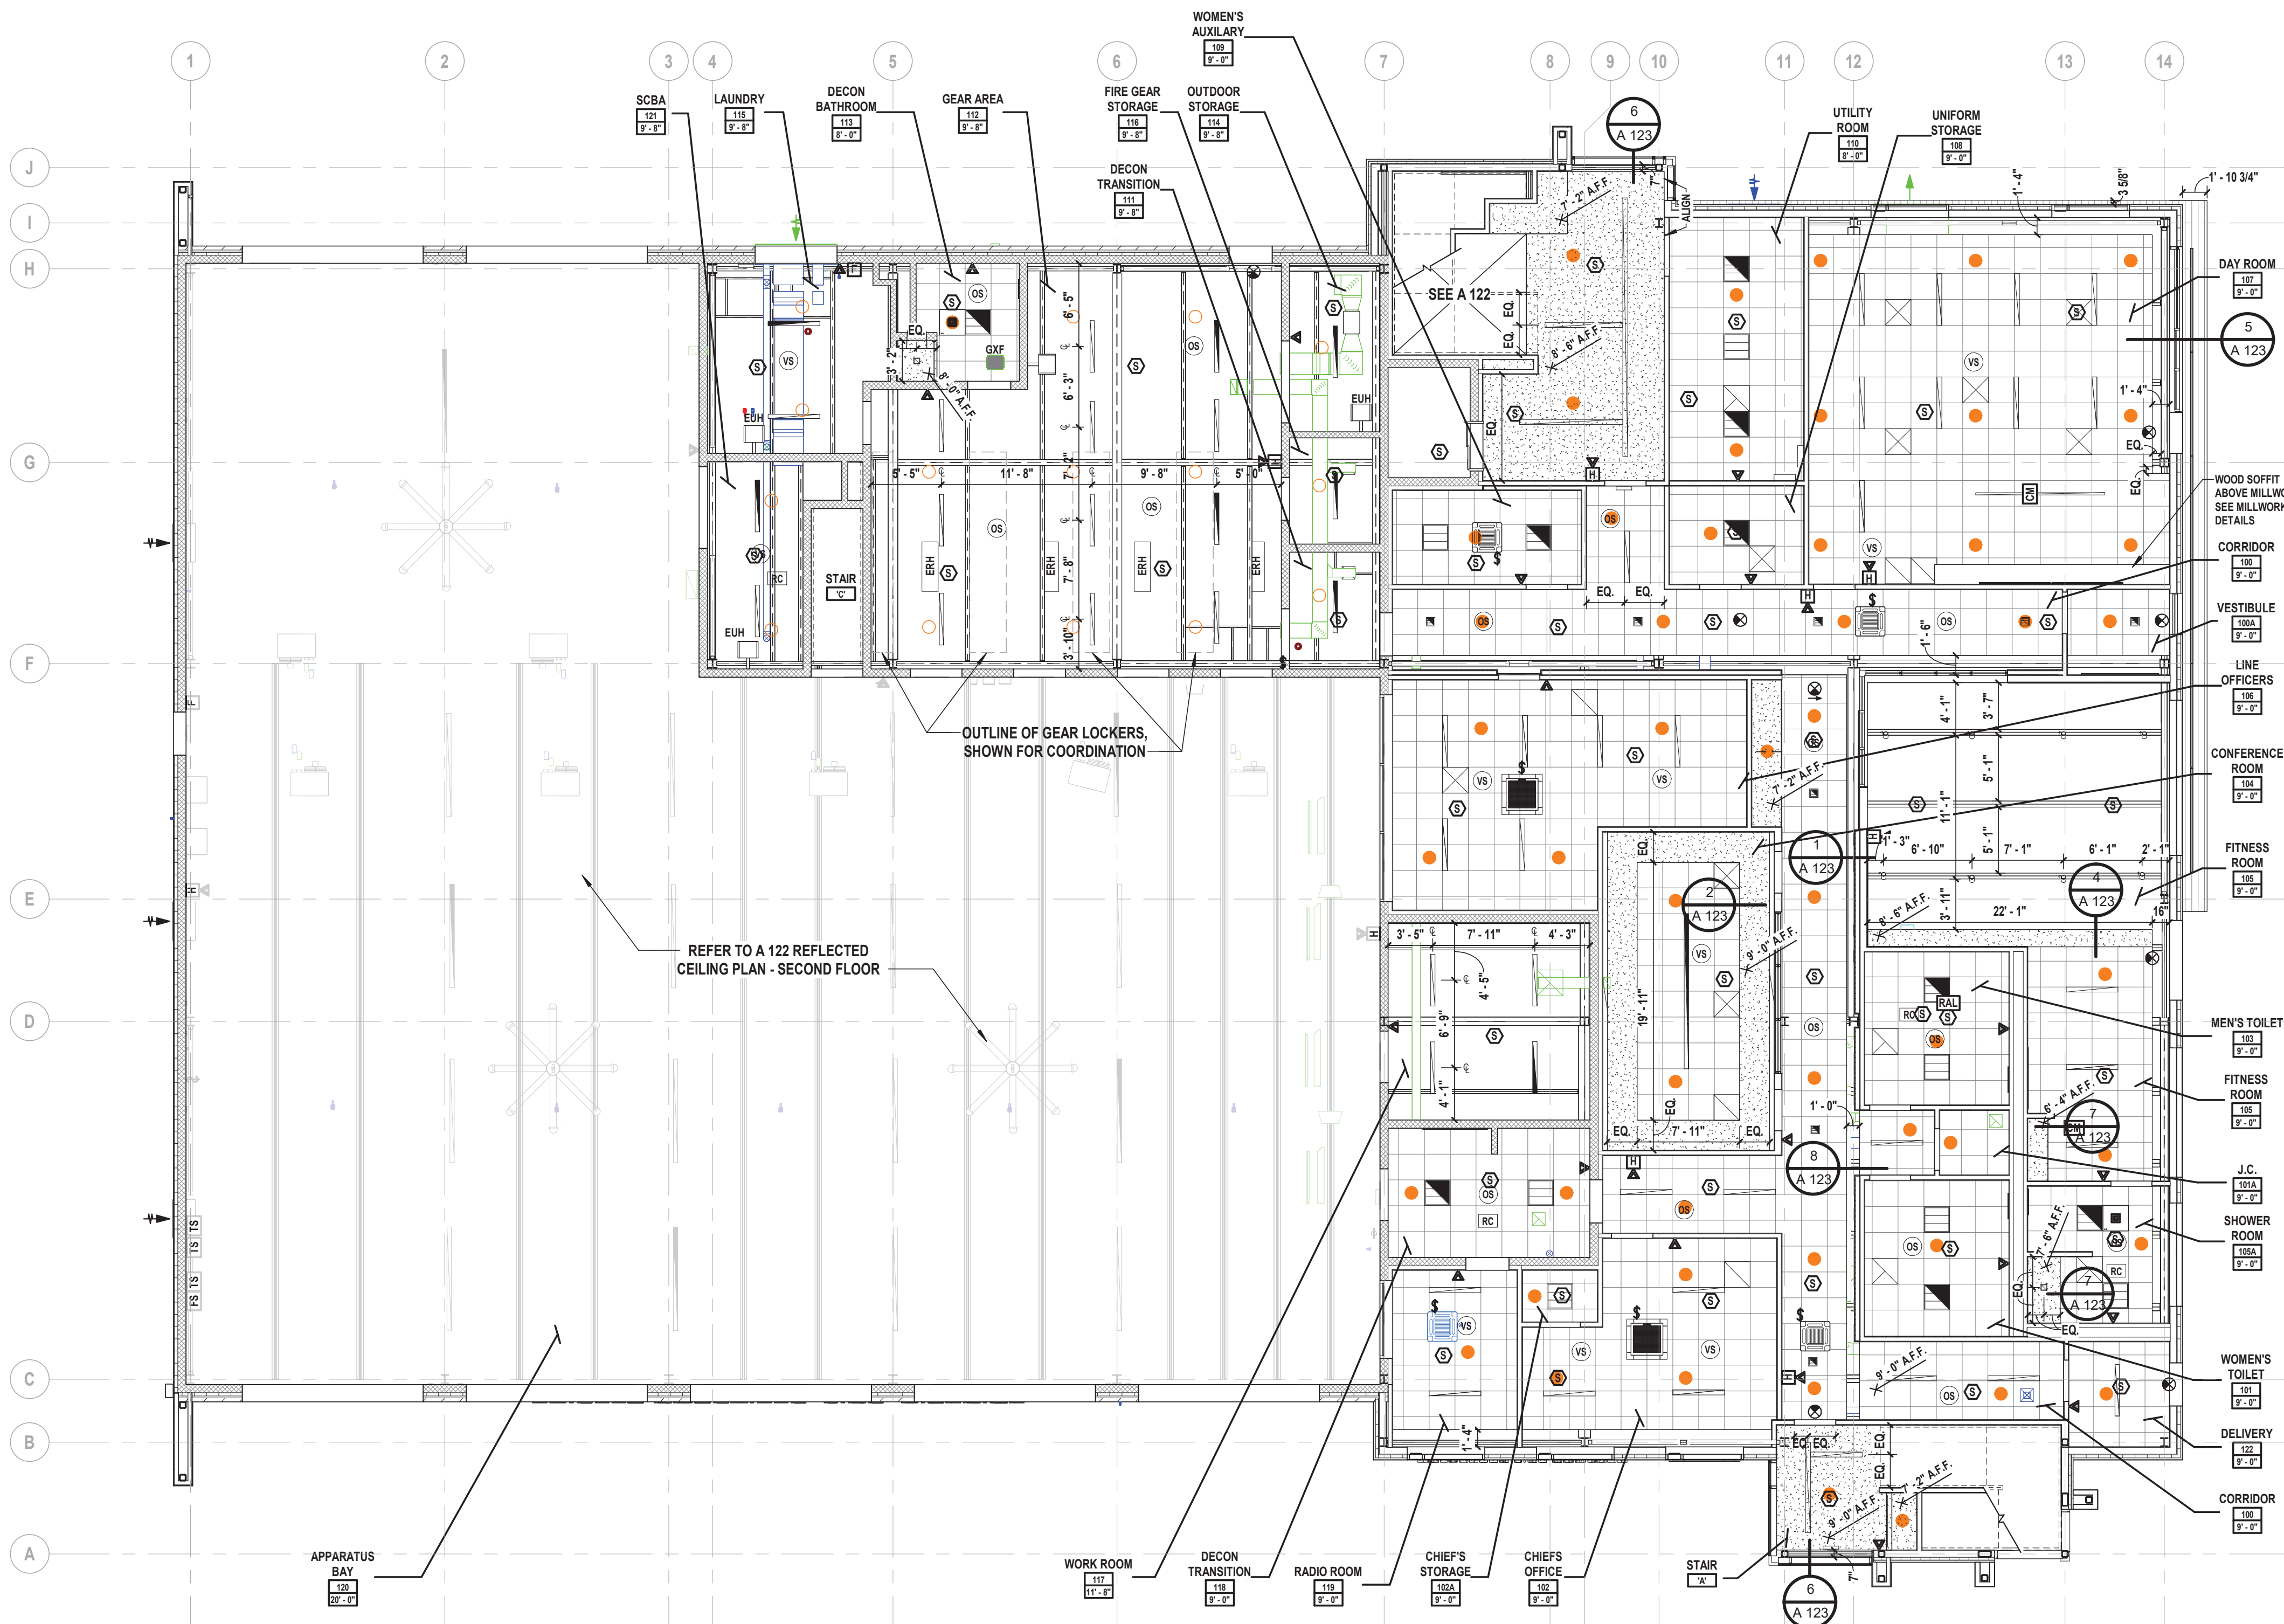

1 First Floor Reflected Ceiling Plan
SCALE: 1/8" = 1'-0"

REFLECTED CEILING PLAN LEGEND	
	2' x 2' ACOUSTICAL CEILING PANEL
	GYPSUM BOARD CEILING, PAINT. PROVIDE MR-GYPSUM BOARD IN SHOWER AREAS
	EXPOSED STRUCTURE, PAINT STRUCTURE AND METAL DECK
	LINEAR METAL CEILING, REFER TO SPECIFICATION FOR ADDITIONAL INFORMATION
	VENTED ALUMINUM SOFFIT - SEE ROOF PLAN FOR ADDITIONAL INFORMATION
	2'x2' LAY-IN FIXTURE - SEE 'E' DRAWINGS FOR ADDITIONAL INFORMATION
	SQUARE RECESSED DOWNLIGHT - SEE 'E' DRAWINGS FOR ADDITIONAL INFORMATION
	PENDANT LIGHT FIXTURE - SEE 'E' DRAWINGS FOR ADDITIONAL INFORMATION
	OCCUPANCY / VACANCY SENSOR, CEILING MOUNTED - SEE 'E' DRAWINGS FOR ADDITIONAL INFORMATION
	FIRE ALARM PULL STATION - SEE 'FA' DRAWINGS FOR ADDITIONAL INFORMATION
	FIRE ALARM HORN / STROBE - SEE 'FA' DRAWINGS FOR ADDITIONAL INFORMATION
	CEILING MOUNTED PROJECTOR PROVIDED BY OWNER, INSTALL BY CONTRACT 'G' - SEE 'E' DRAWINGS FOR ADDITIONAL INFORMATION
	SIDEWALL SPRINKLER - SEE 'FP' DRAWINGS FOR ADDITIONAL INFORMATION
	HEAT / SMOKE DETECTOR - SEE 'FA' DRAWINGS FOR ADDITIONAL INFORMATION
	CONCEALED / EXPOSED PENDENT SPRINKLER HEAD - SEE 'FP' DRAWINGS FOR ADDITIONAL INFORMATION
	CEILING MOUNTED INDOOR VRF CASSETTE - SEE 'M' DRAWINGS FOR ADDITIONAL INFORMATION
	SUPPLY DIFFUSER - SEE 'M' DRAWINGS FOR ADDITIONAL INFORMATION
	ELECTRIC UNIT HEATERS - SEE 'M' DRAWINGS FOR ADDITIONAL INFORMATION
	GENERAL EXHAUST FANS - SEE 'M' DRAWINGS FOR ADDITIONAL INFORMATION
	ELECTRIC RADIANT - SEE 'M' DRAWINGS FOR ADDITIONAL INFORMATION
	UNIT HEATER MOUNTED TO STRUCTURE ABOVE - SEE 'M' DRAWINGS FOR ADDITIONAL INFORMATION
	UPRIGHT SPRINKLER HEAD - SEE 'FP' DRAWINGS FOR ADDITIONAL INFORMATION

REFLECTED CEILING PLAN NOTES	
1.	CONTRACTOR IS TO COORDINATE ALL THE WORK REQUIRED ON THIS DRAWING WITH ALL ARCHITECTURAL, STRUCTURAL, & MEP DRAWINGS AND SPECIFICATIONS.
2.	CONTRACTOR IS TO CENTER THE CEILING GRID AND COORDINATE GRID LAYOUT TO PROVIDE NO SLIVER PIECES LESS THAN 3".
3.	CONTRACTOR TO PROVIDE COORDINATION DRAWINGS FOR ALL EQUIPMENT AND LIGHTING PRIOR TO CONSTRUCTION.
4.	CONTRACTOR, ARCHITECT AND OWNER TO HAVE A CEILING COORDINATION MEETING PRIOR TO ORDERING MATERIALS.
5.	ACCOMMODATE THE CONSTRUCTION TO ACCEPT ALL PIPING, CONDUITS, EQUIPMENT, ETC., EITHER SPECIFIED OR DETAILED TO BE RECESSED OR CONCEALED IN MASONRY WALLS AS REQUIRED BY THIS CONTRACT. COORDINATE THE LOCATION OF ANY RECESSED OR CONCEALED ITEMS.
6.	SEE CEILING DETAILS ON DRAWING A 123 FOR ADDITIONAL INFORMATION.

H2M architects + engineers

538 Broad Hollow Road, 4th Floor East
Melville, NY 11747
631.756.8000 • www.h2m.com
NY Architecture & Landscape Architecture: No Certificate Required
NY Engineering Certificate of Authorization No.: 0018178

CONSULTANTS:		

MARK	DATE	DESCRIPTION

PATRICK O. STONE, R.A.
NY PROFESSIONAL ARCHITECT LIC. NO. 029654
10/31/2025
Exp. Date

IN ACCORDANCE WITH ARTICLE 145, SECTION 1209 OF THE NYS EDUCATION LAW, ALTERNATION OF THIS DOCUMENT EXCEPT BY A LICENSED PROFESSIONAL IS ILLEGAL.

DESIGNED BY:	DRAWN BY:	CHECKED BY:	REVIEWED BY:
DBS/RLG	ANK	DBS	POS

PROJECT No: TRFD 2302 DATE: FEBRUARY 2025 SCALE: AS SHOWN

CLIENT

**THIELLS
ROSEVILLE FIRE
DISTRICT**

NEW 26-100 FIRE
HEADQUARTERS

65 W RAMAPO ROAD
GARNERVILLE, NY 10923

CONTRACT

**CONTRACT G
GENERAL CONSTRUCTION**

STATUS


FINAL BID DOCUMENT

SHEET TITLE

**REFLECTED CEILING PLAN - FIRST
FLOOR**

DRAWING No.

A 121.00

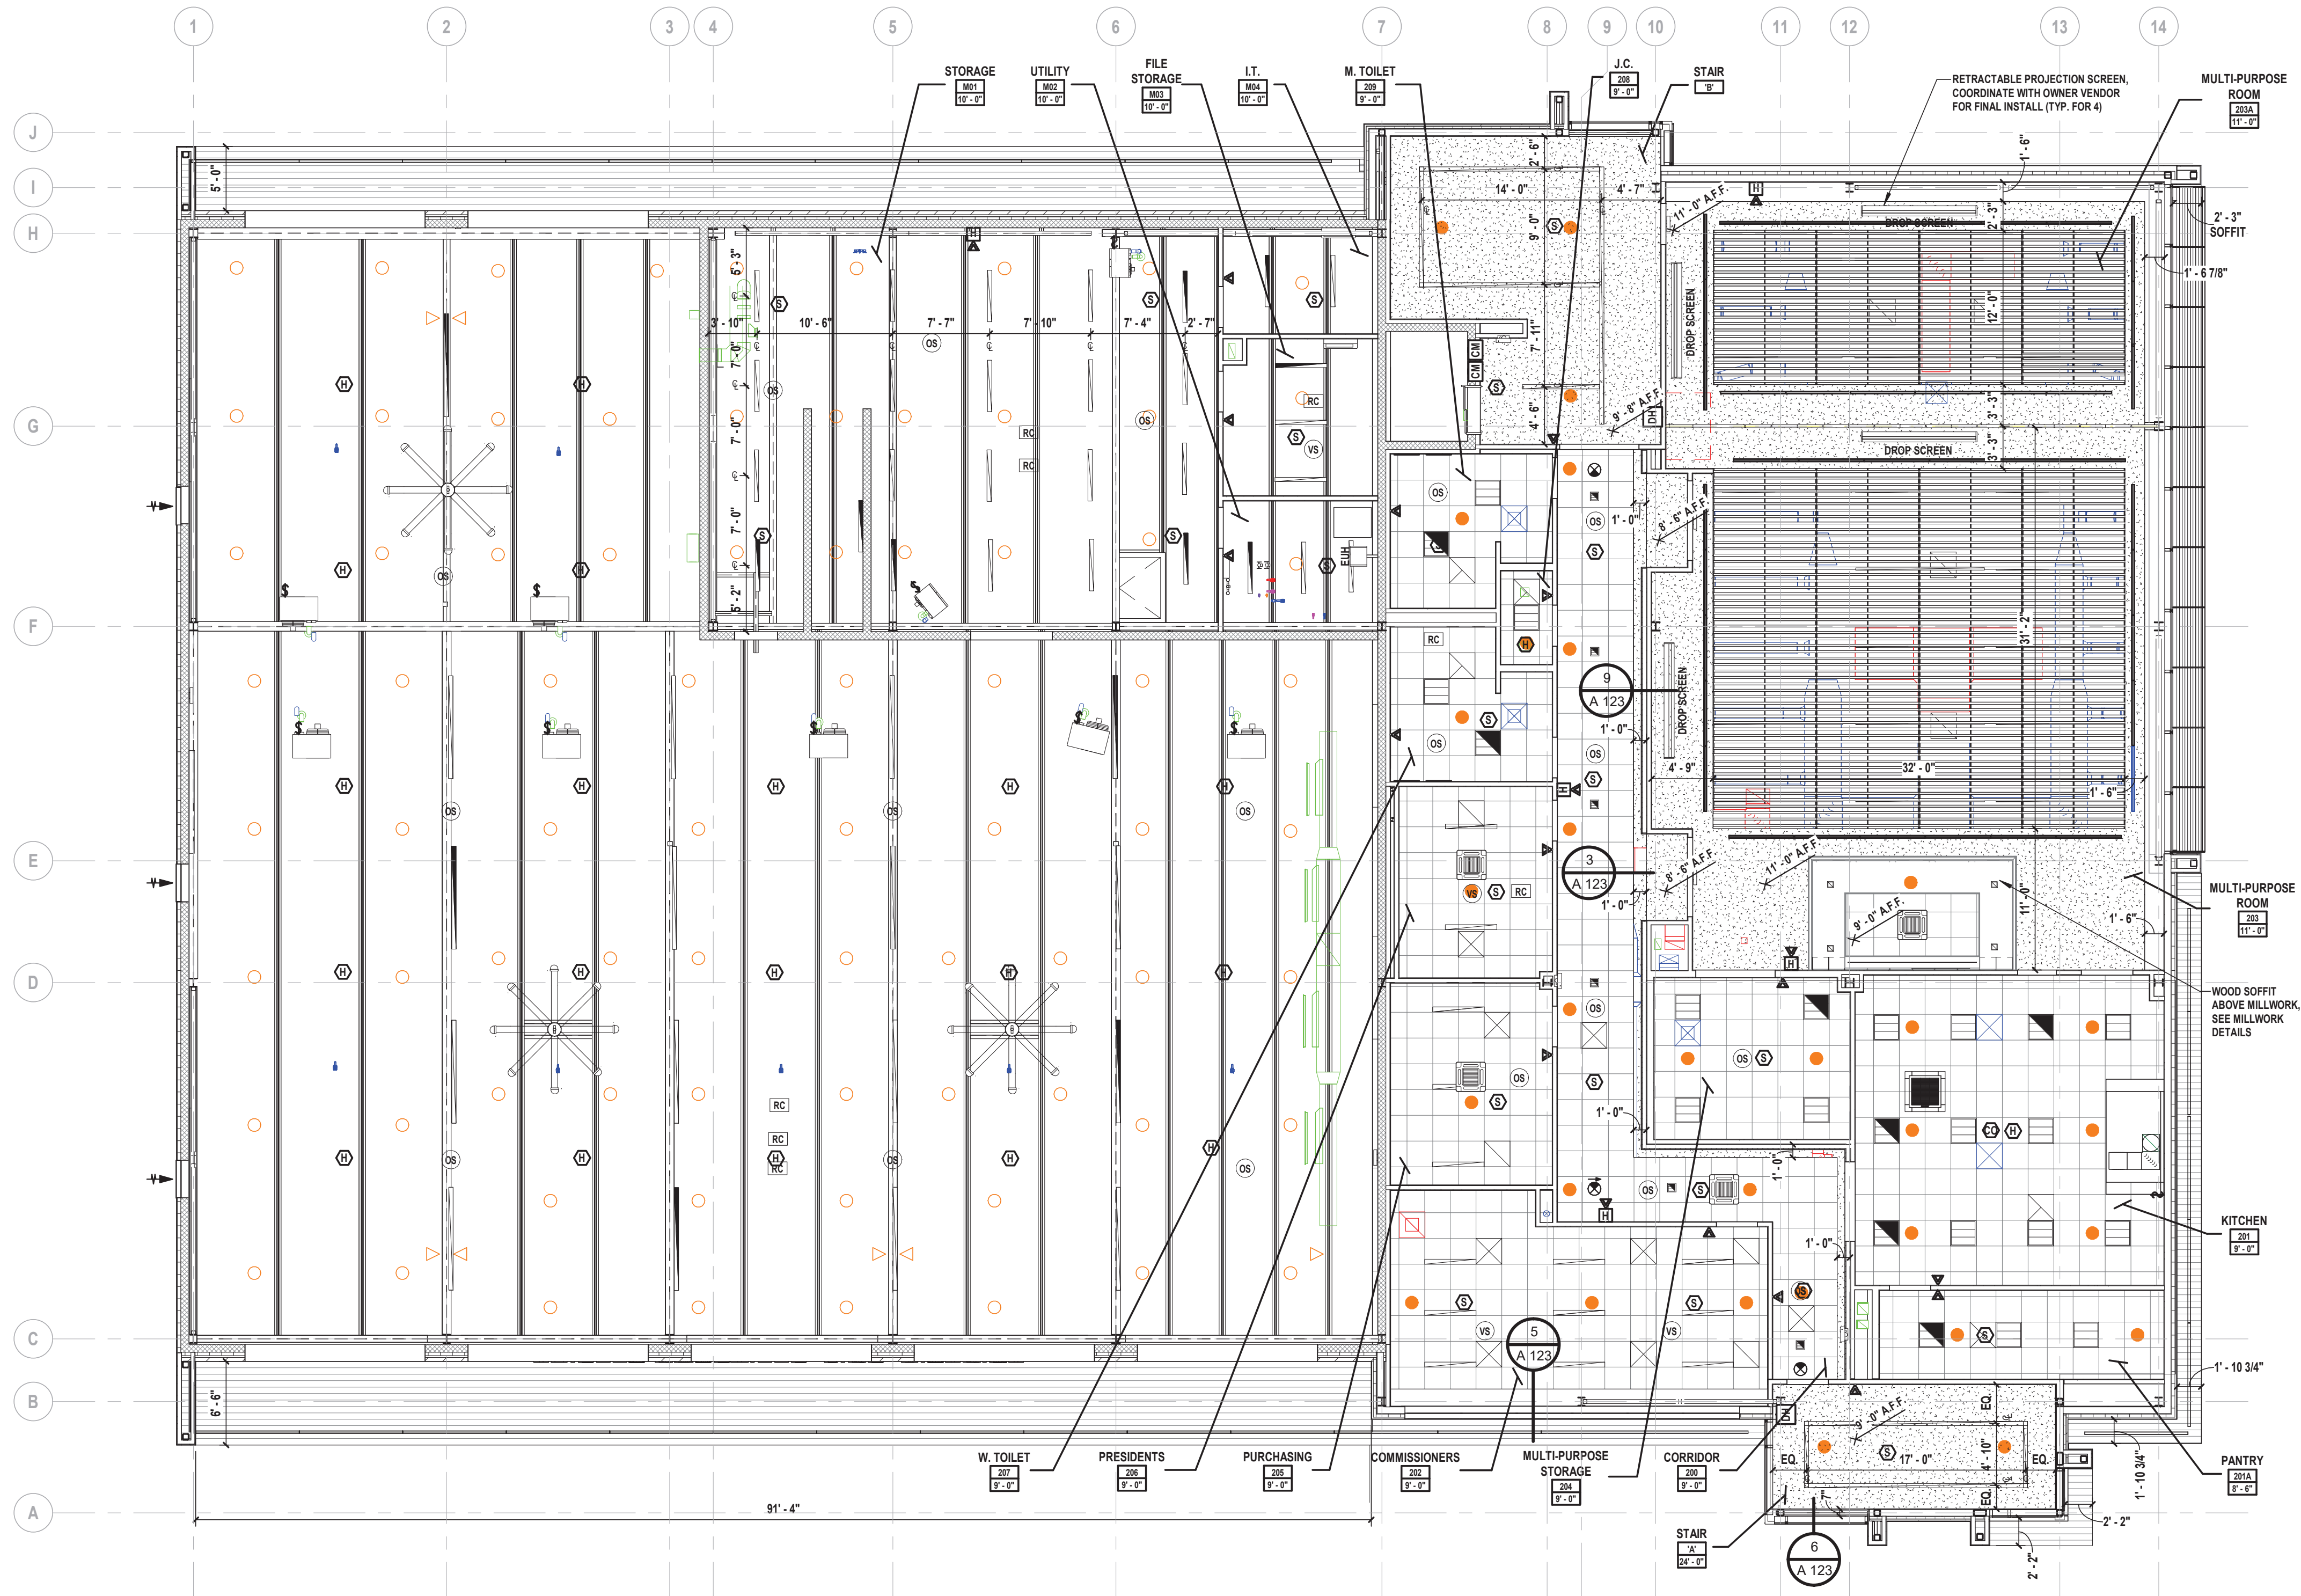

1 Second Floor Reflected Ceiling Plan
SCALE: 1/8" = 1'-0"

REFLECTED CEILING PLAN LEGEND	
	2' x 2' ACOUSTICAL CEILING PANEL
	GYPSUM BOARD CEILING, PAINT. PROVIDE MR-GYPSUM BOARD IN SHOWER AREAS
	EXPOSED STRUCTURE, PAINT STRUCTURE AND METAL DECK
	LINEAR METAL CEILING, REFER TO SPECIFICATION FOR ADDITIONAL INFORMATION
	VENTED ALUMINUM SOFFIT - SEE ROOF PLAN FOR ADDITIONAL INFORMATION
	2'x2' LAY-IN FIXTURE - SEE 'E' DRAWINGS FOR ADDITIONAL INFORMATION
	SQUARE RECESSED DOWNLIGHT - SEE 'E' DRAWINGS FOR ADDITIONAL INFORMATION
	PENDANT LIGHT FIXTURE - SEE 'E' DRAWINGS FOR ADDITIONAL INFORMATION
	OCCUPANCY / VACANCY SENSOR, CEILING MOUNTED - SEE 'E' DRAWINGS FOR ADDITIONAL INFORMATION
	FIRE ALARM PULL STATION - SEE 'FA' DRAWINGS FOR ADDITIONAL INFORMATION
	FIRE ALARM HORN / STROBE - SEE 'FA' DRAWINGS FOR ADDITIONAL INFORMATION
	CEILING MOUNTED PROJECTOR PROVIDED BY OWNER, INSTALL BY CONTRACT 'G' - SEE 'E' DRAWINGS FOR ADDITIONAL INFORMATION
	SIDEWALL SPRINKLER - SEE 'FP' DRAWINGS FOR ADDITIONAL INFORMATION
	HEAT / SMOKE DETECTOR - SEE 'FA' DRAWINGS FOR ADDITIONAL INFORMATION
	CONCEALED / EXPOSED PENDENT SPRINKLER HEAD - SEE 'FP' DRAWINGS FOR ADDITIONAL INFORMATION
	CEILING MOUNTED INDOOR VRF CASSETTE - SEE 'M' DRAWINGS FOR ADDITIONAL INFORMATION
	SUPPLY DIFFUSER - SEE 'M' DRAWINGS FOR ADDITIONAL INFORMATION
	ELECTRIC UNIT HEATERS - SEE 'M' DRAWINGS FOR ADDITIONAL INFORMATION
	GENERAL EXHAUST FANS - SEE 'M' DRAWINGS FOR ADDITIONAL INFORMATION
	ELECTRIC RADIANT - SEE 'M' DRAWINGS FOR ADDITIONAL INFORMATION
	UNIT HEATER MOUNTED TO STRUCTURE ABOVE - SEE 'M' DRAWINGS FOR ADDITIONAL INFORMATION
	UPRIGHT SPRINKLER HEAD - SEE 'FP' DRAWINGS FOR ADDITIONAL INFORMATION

REFLECTED CEILING PLAN NOTES	
1.	CONTRACTOR IS TO COORDINATE ALL THE WORK REQUIRED ON THIS DRAWING WITH ALL ARCHITECTURAL, STRUCTURAL, & MEP DRAWINGS AND SPECIFICATIONS.
2.	CONTRACTOR IS TO CENTER THE CEILING GRID AND COORDINATE GRID LAYOUT TO PROVIDE NO SLIVER PIECES LESS THAN 3".
3.	CONTRACTOR TO PROVIDE COORDINATION DRAWINGS FOR ALL EQUIPMENT AND LIGHTING PRIOR TO CONSTRUCTION.
4.	CONTRACTOR, ARCHITECT AND OWNER TO HAVE A CEILING COORDINATION MEETING PRIOR TO ORDERING MATERIALS.
5.	ACCOMMODATE THE CONSTRUCTION TO ACCEPT ALL PIPING, CONDUITS, EQUIPMENT, ETC., EITHER SPECIFIED OR DETAILED TO BE RECESSED OR CONCEALED IN MASONRY WALLS AS REQUIRED BY THIS CONTRACT. COORDINATE THE LOCATION OF ANY RECESSED OR CONCEALED ITEMS.
6.	SEE CEILING DETAILS ON DRAWING A 123 FOR ADDITIONAL INFORMATION.

CONSULTANTS:		

MARK	DATE	DESCRIPTION

PATRICK O. STONE, R.A.
NY PROFESSIONAL ARCHITECT LIC. NO. 029654
Exp. Date: 10/31/2025

"IN ACCORDANCE WITH ARTICLE 145, SECTION 1209 OF THE NYS EDUCATION LAW, ALTERNATION OF THIS DOCUMENT EXCEPT BY A LICENSED PROFESSIONAL IS ILLEGAL."

DESIGNED BY:	DRAWN BY:	CHECKED BY:	REVIEWED BY:
DBS/RLG	ANK	DBS	POS

PROJECT No: TRFD 2302 DATE: FEBRUARY 2025 SCALE: AS SHOWN

CLIENT

**THIELLS
ROSEVILLE FIRE
DISTRICT**

NEW 26-100 FIRE
HEADQUARTERS


65 W RAMAPO ROAD
GARNERVILLE, NY 10923

CONTRACT
CONTRACT G GENERAL CONSTRUCTION


STATUS
FINAL BID DOCUMENT

SHEET TITLE
REFLECTED CEILING PLAN - SECOND FLOOR


DRAWING No.
A 122.00

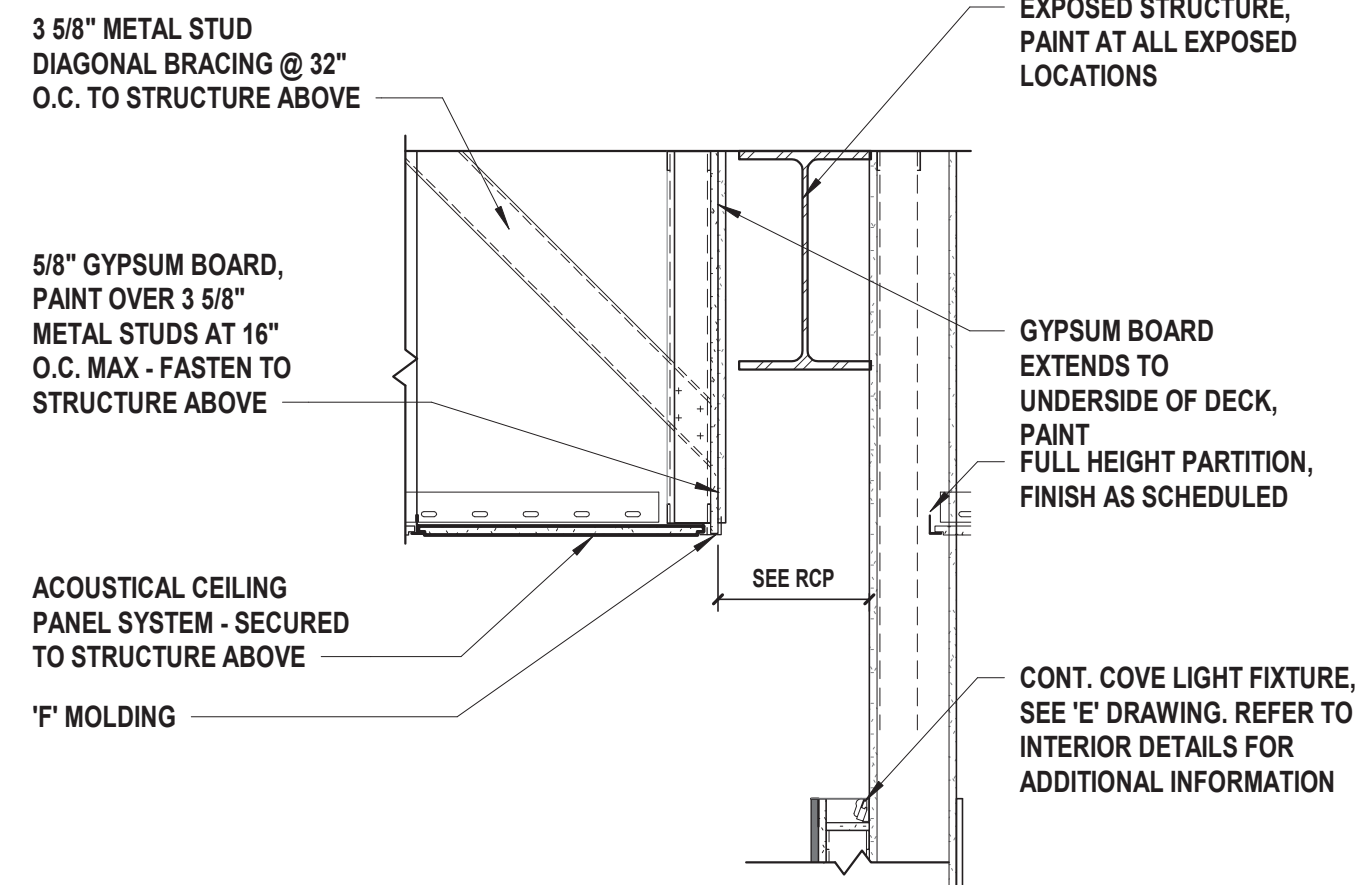


① Ceiling Detail - Typ. Corridor
SCALE: 3/4" = 1'-0"

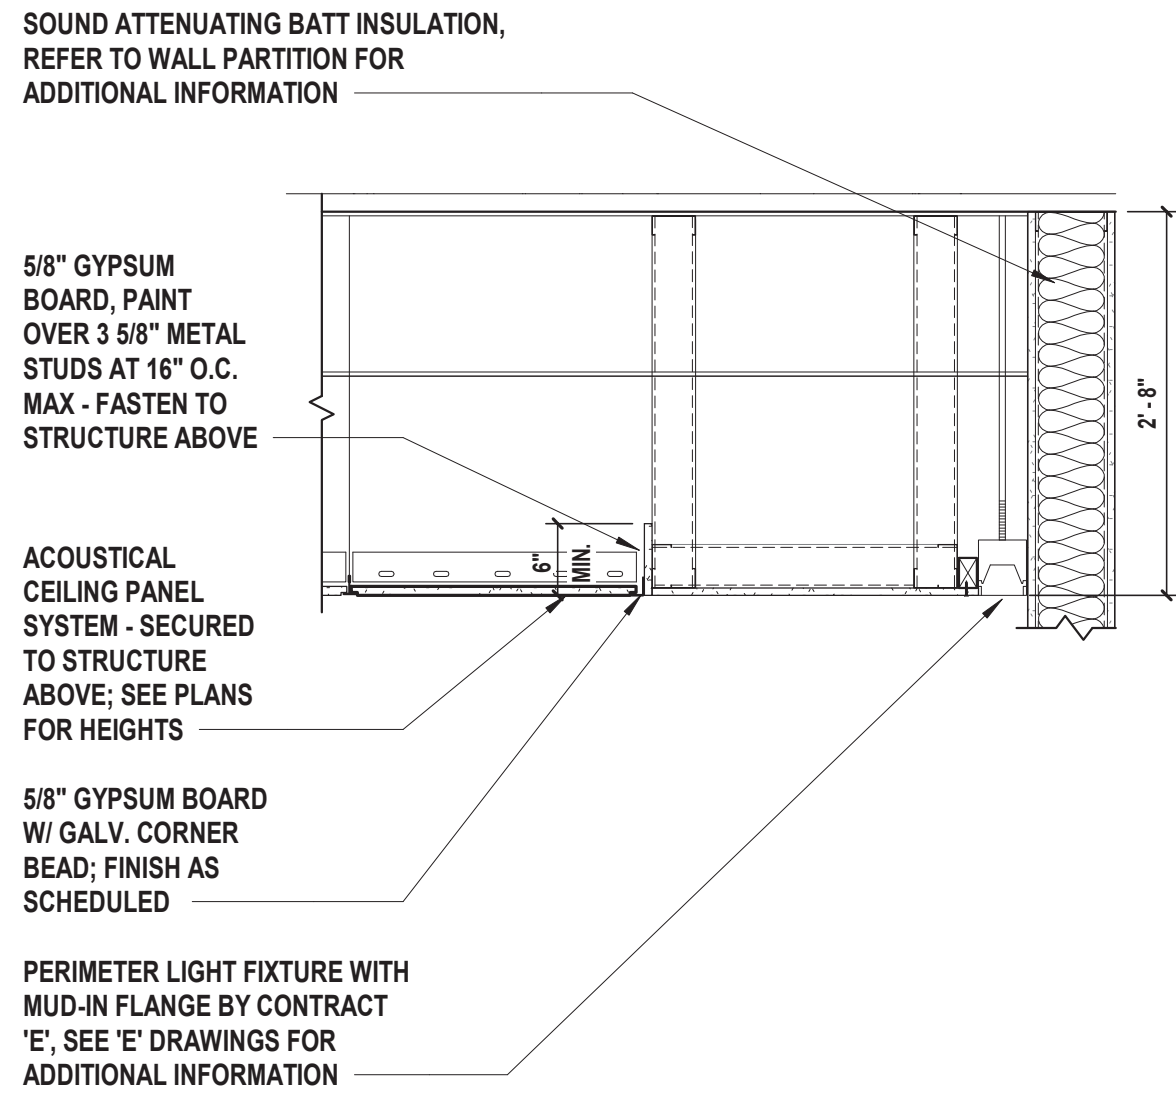


② Ceiling Detail - Conference Room
SCALE: 3/4" = 1'-0"

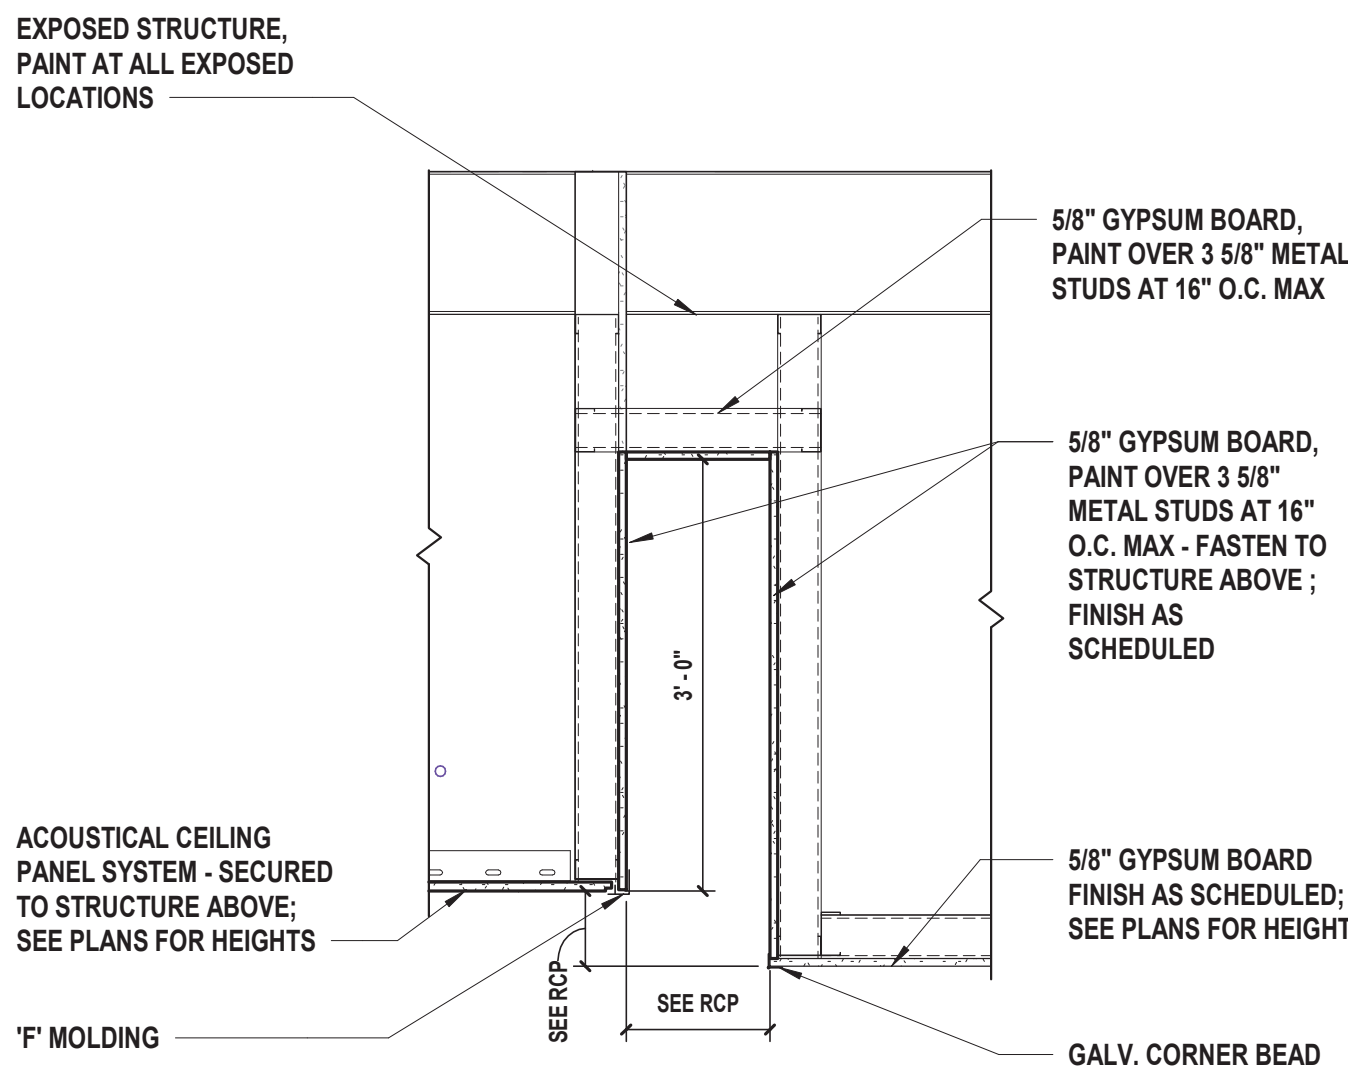


③ Corridor and Soffit
SCALE: 3/4" = 1'-0"

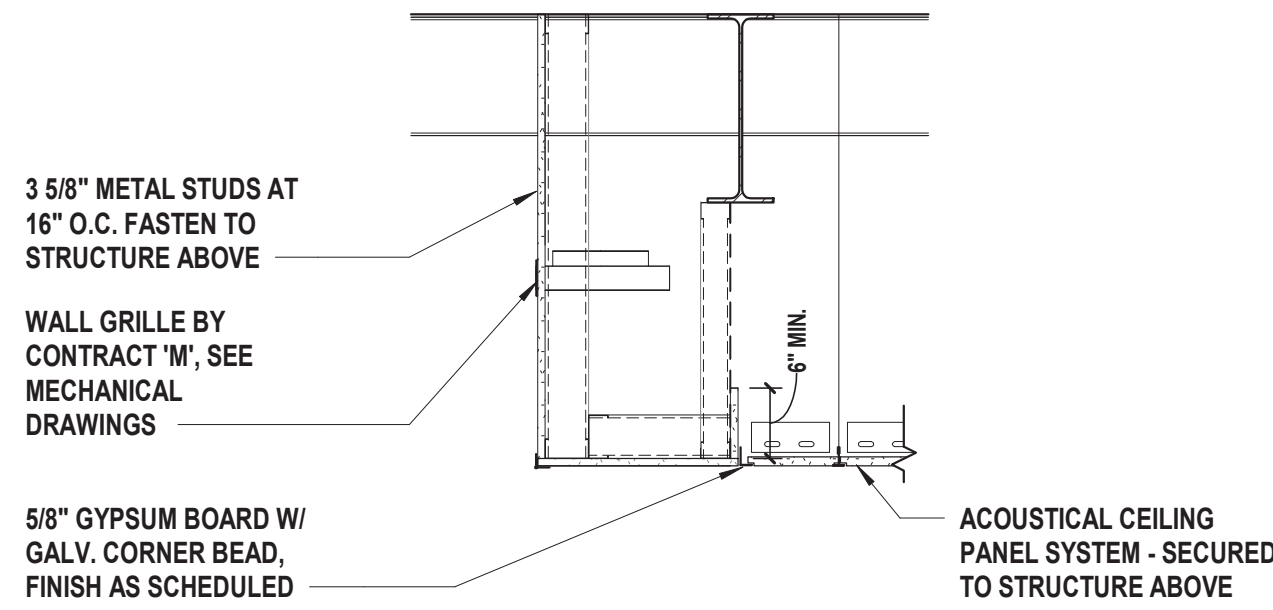


④ Ceiling Detail - Fitness Room Soffit
SCALE: 3/4" = 1'-0"

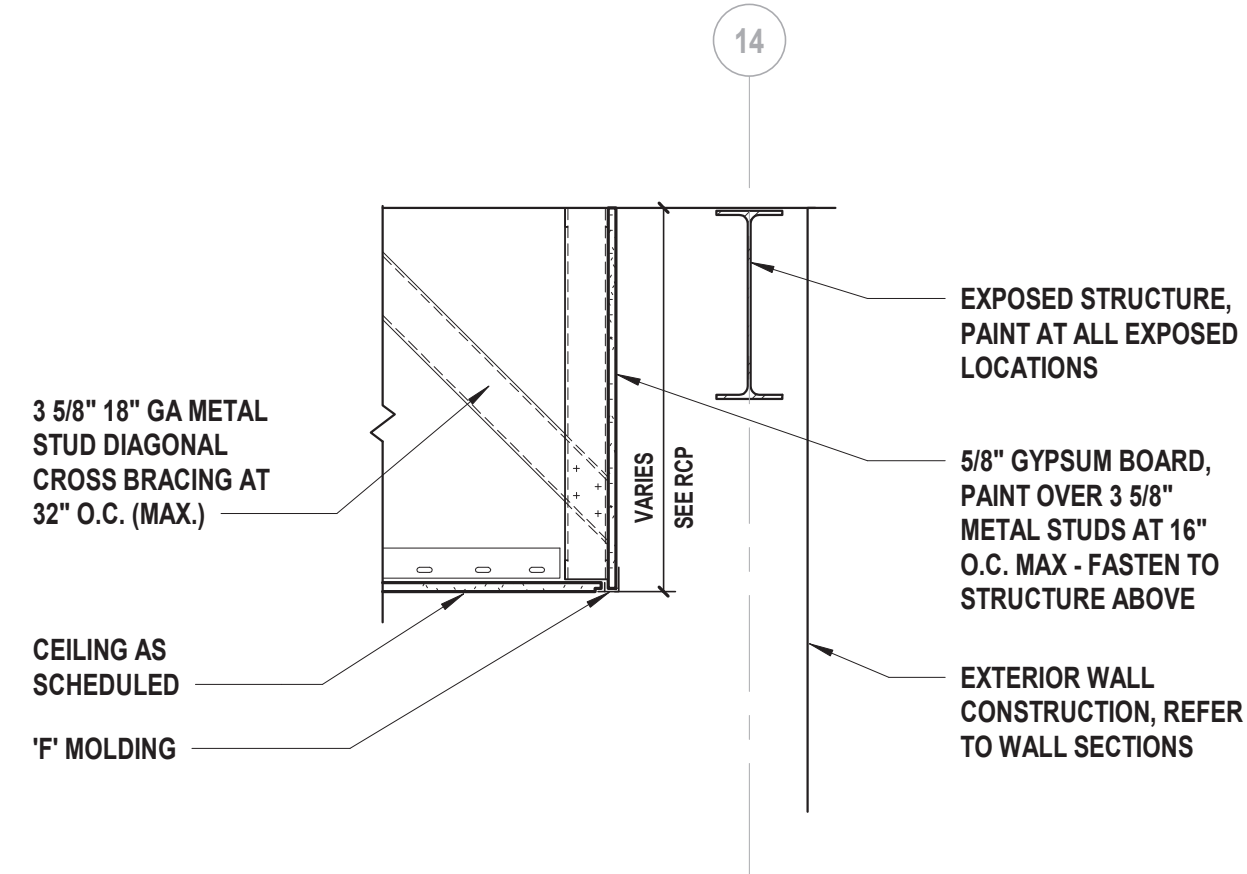


⑤ Ceiling Detail - Perimeter, Typ.
SCALE: 3/4" = 1'-0"

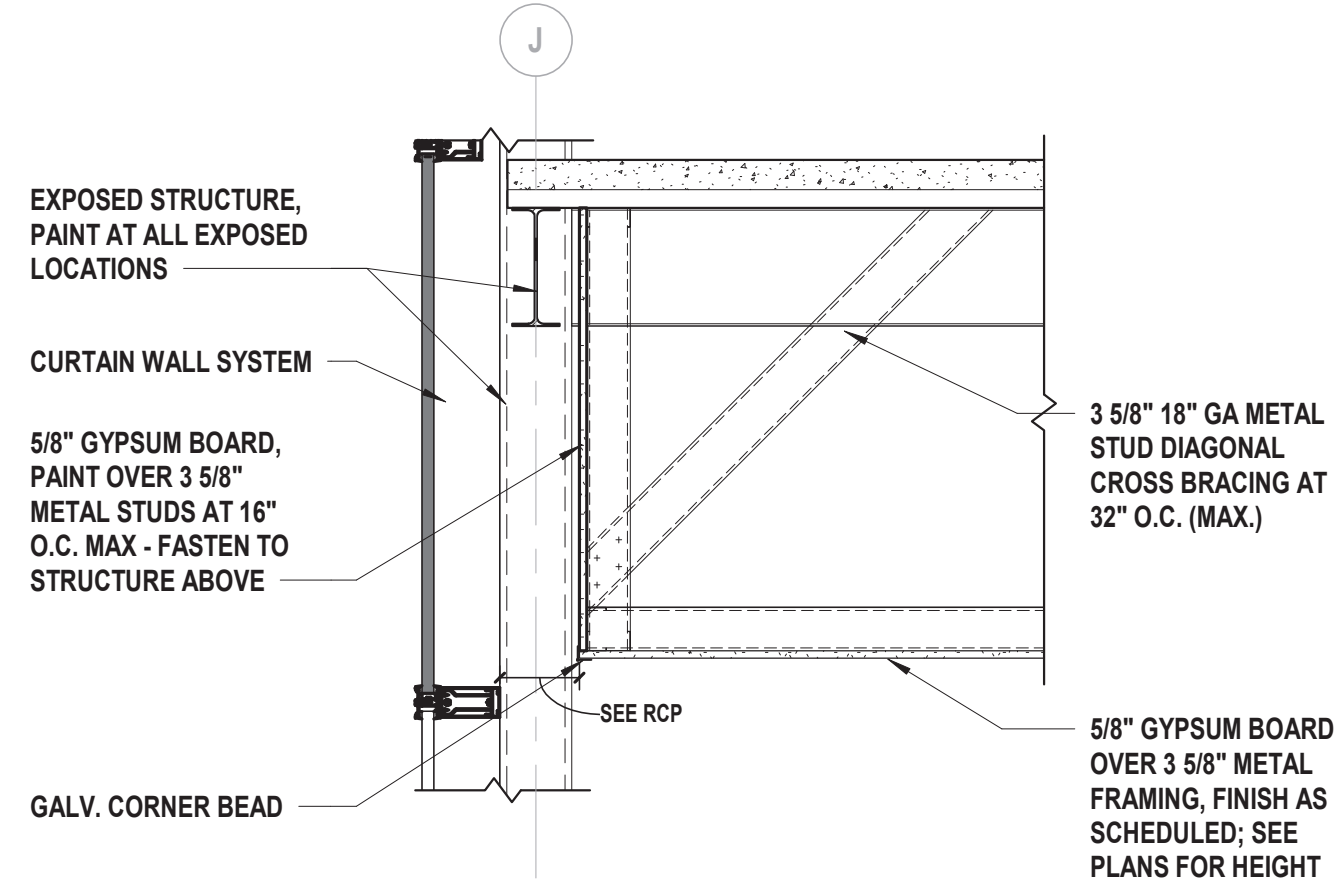


⑥ Ceiling Detail -Typical
SCALE: 3/4" = 1'-0"

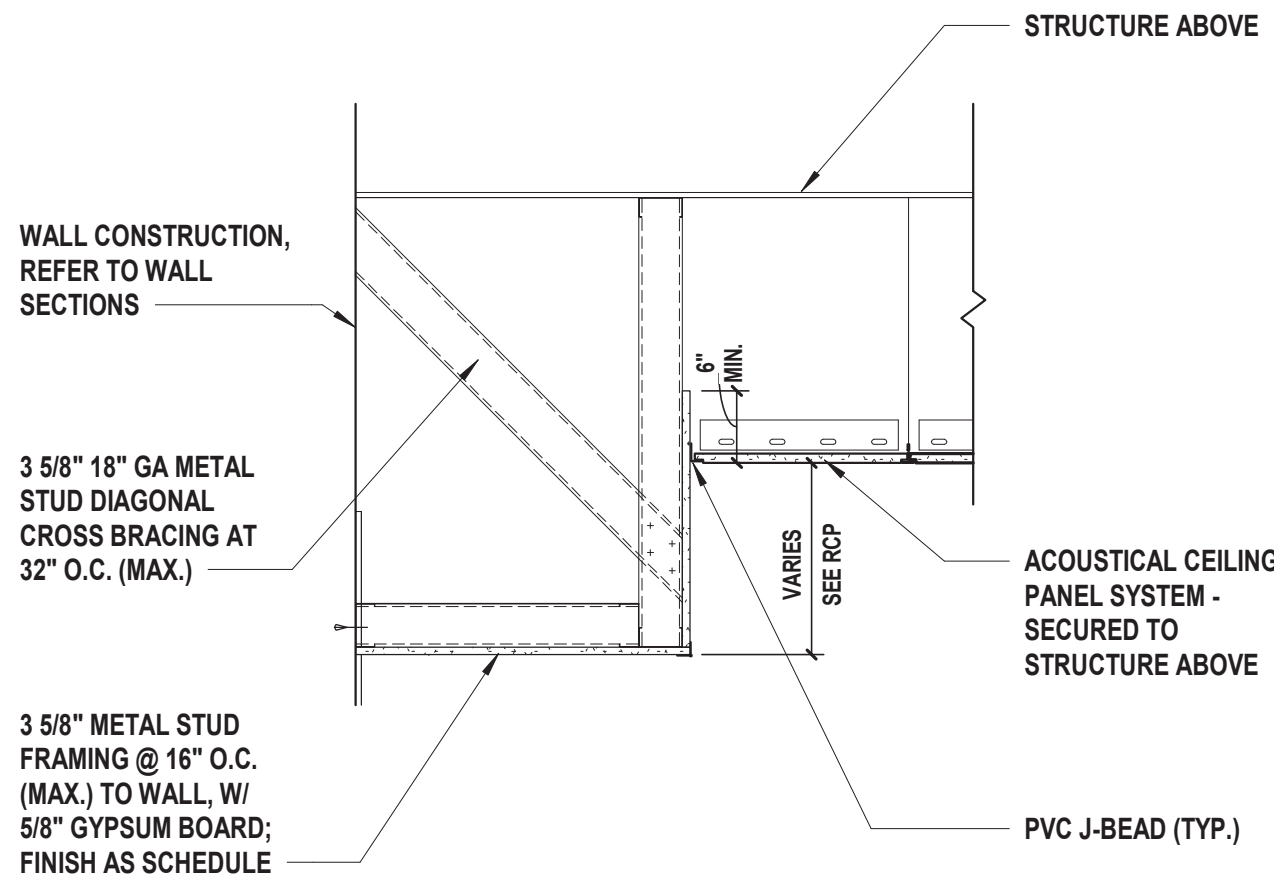


⑦ Ceiling Soffit Detail
SCALE: 3/4" = 1'-0"

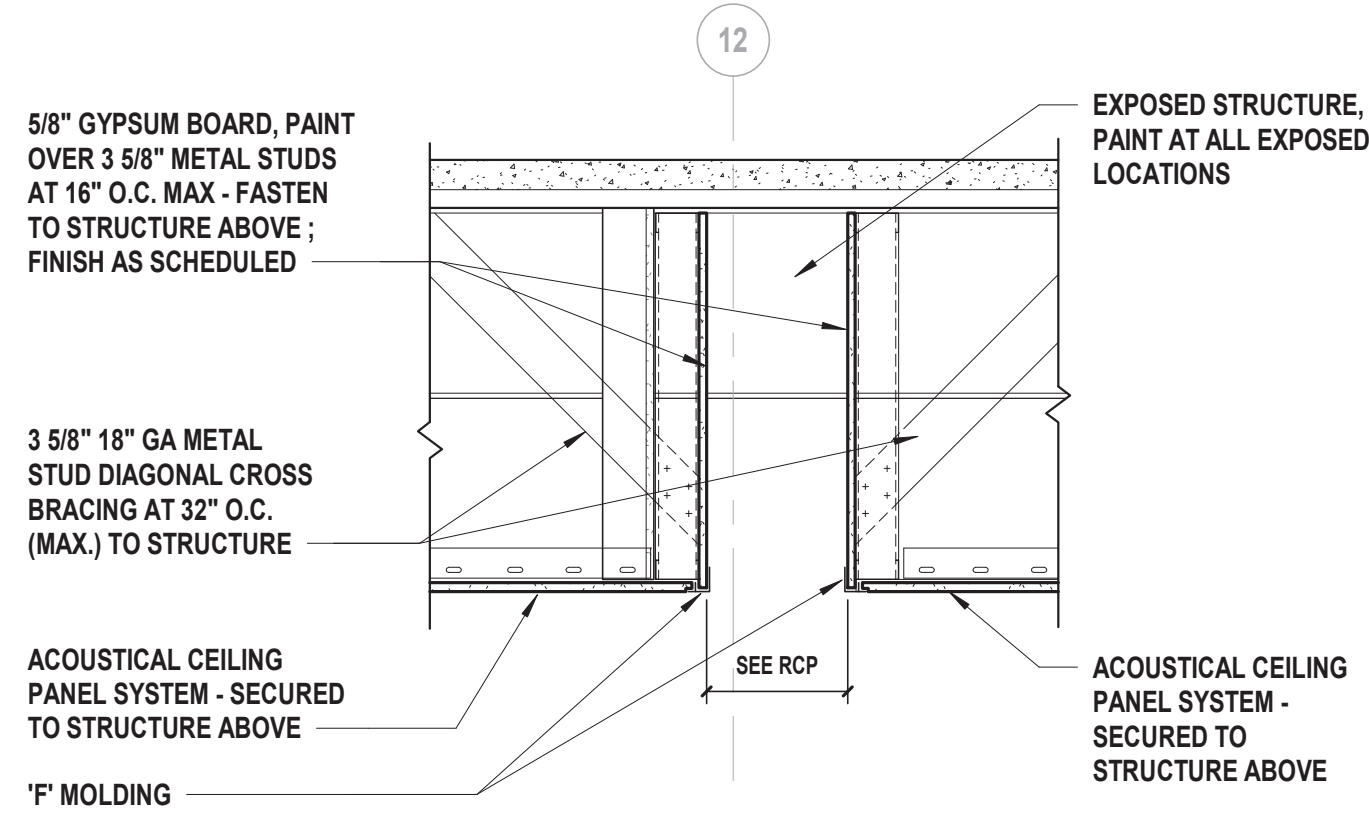


⑧ Ceiling Detail
SCALE: 3/4" = 1'-0"

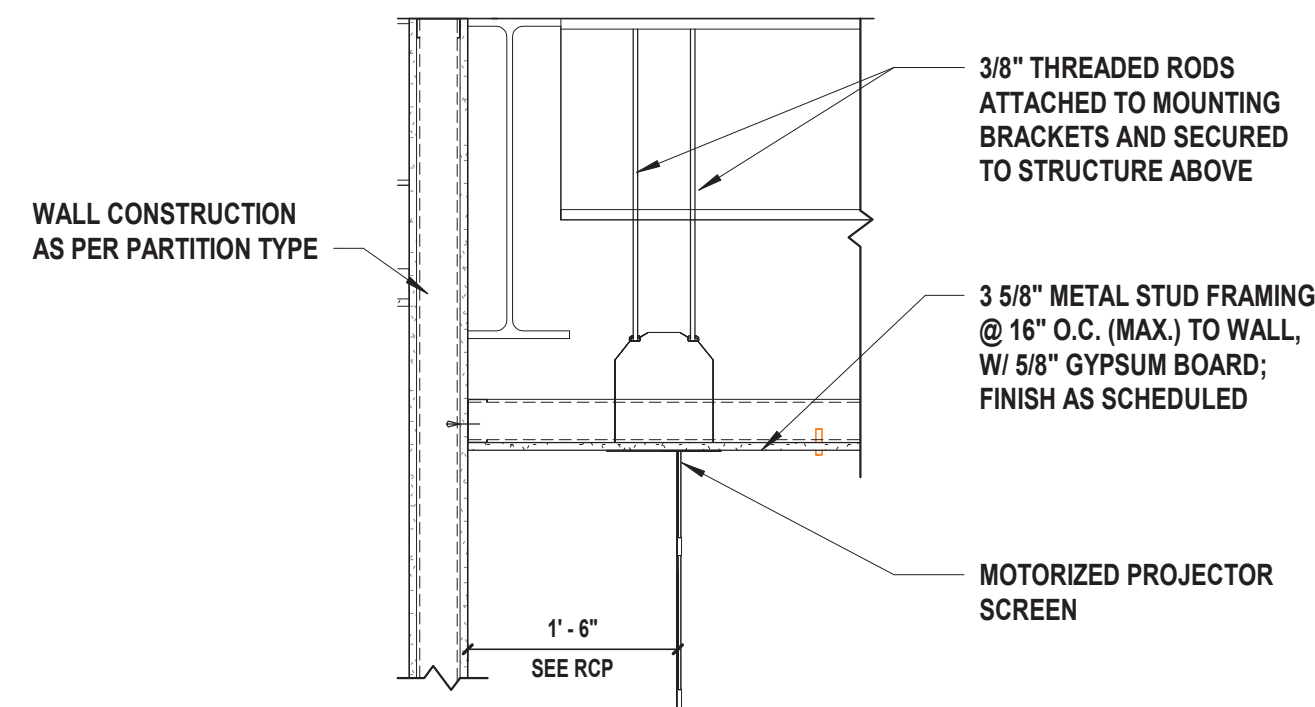

⑨ Ceiling Detail - Projector Screen Detail
SCALE: 3/4" = 1'-0"

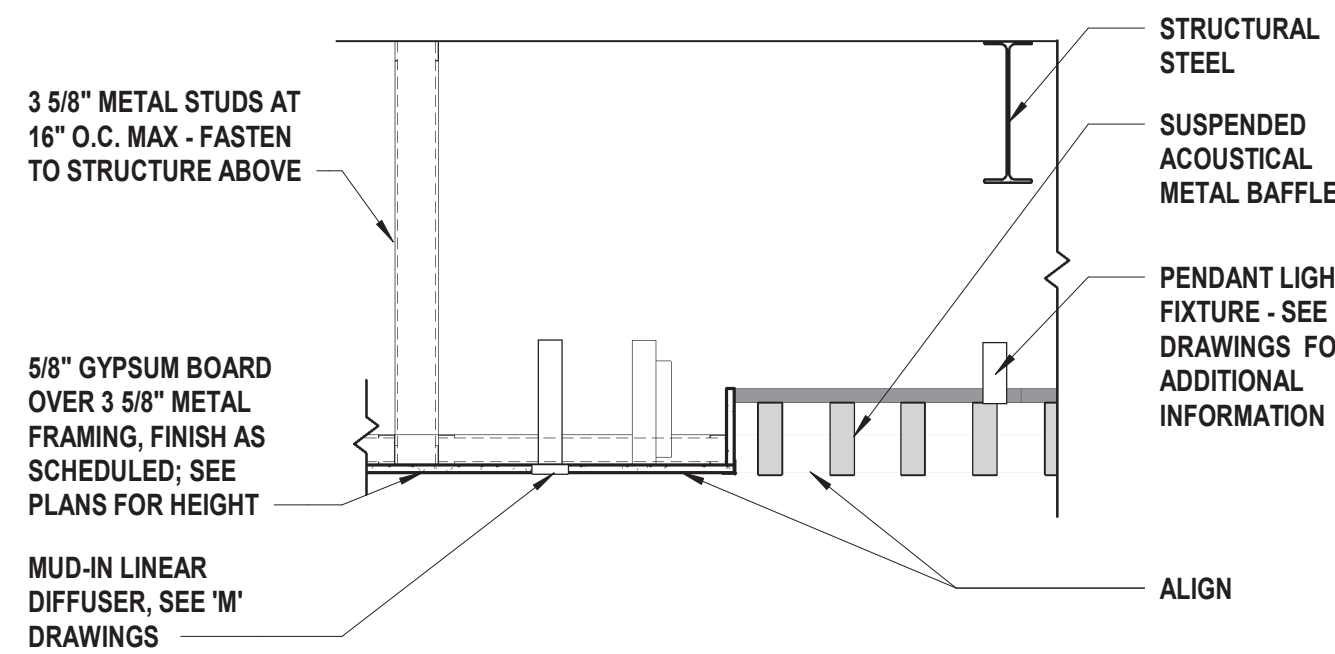


⑩ Acoustical Suspended Baffle Ceiling Detail
SCALE: 3/4" = 1'-0"

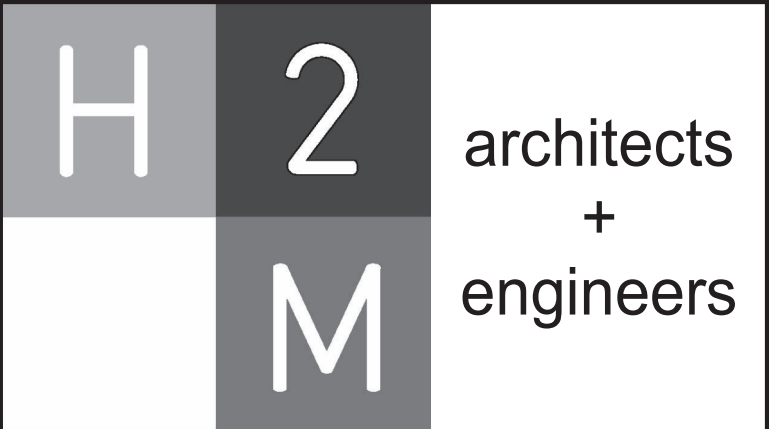

538 Broad Hollow Road, 4th Floor East
Melville, NY 11747
631.756.8000 • www.h2m.com
NY Architecture & Landscape Architecture: No Certificate Required
NY Engineering Certificate of Authorization No.: 0018178

CONSULTANTS:		

MARK	DATE	DESCRIPTION

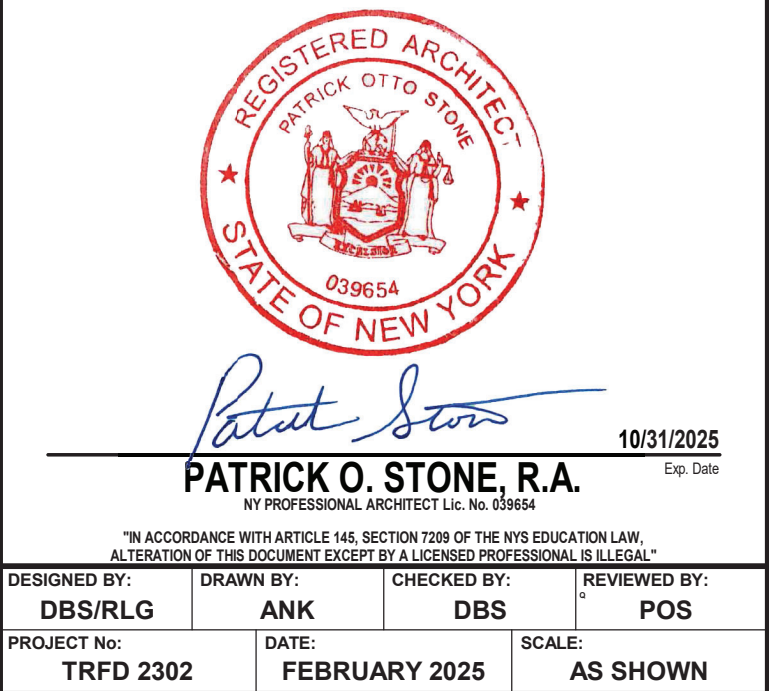

CLIENT

**THIELLS
ROSEVILLE FIRE
DISTRICT**

**NEW 26-100 FIRE
HEADQUARTERS**

**65 W RAMAPO ROAD
GARNERVILLE, NY 10923**

CONTRACT

**CONTRACT G
GENERAL CONSTRUCTION**

STATUS


FINAL BID DOCUMENT

SHEET TITLE

CEILING DETAILS

DRAWING No.

A 123.00

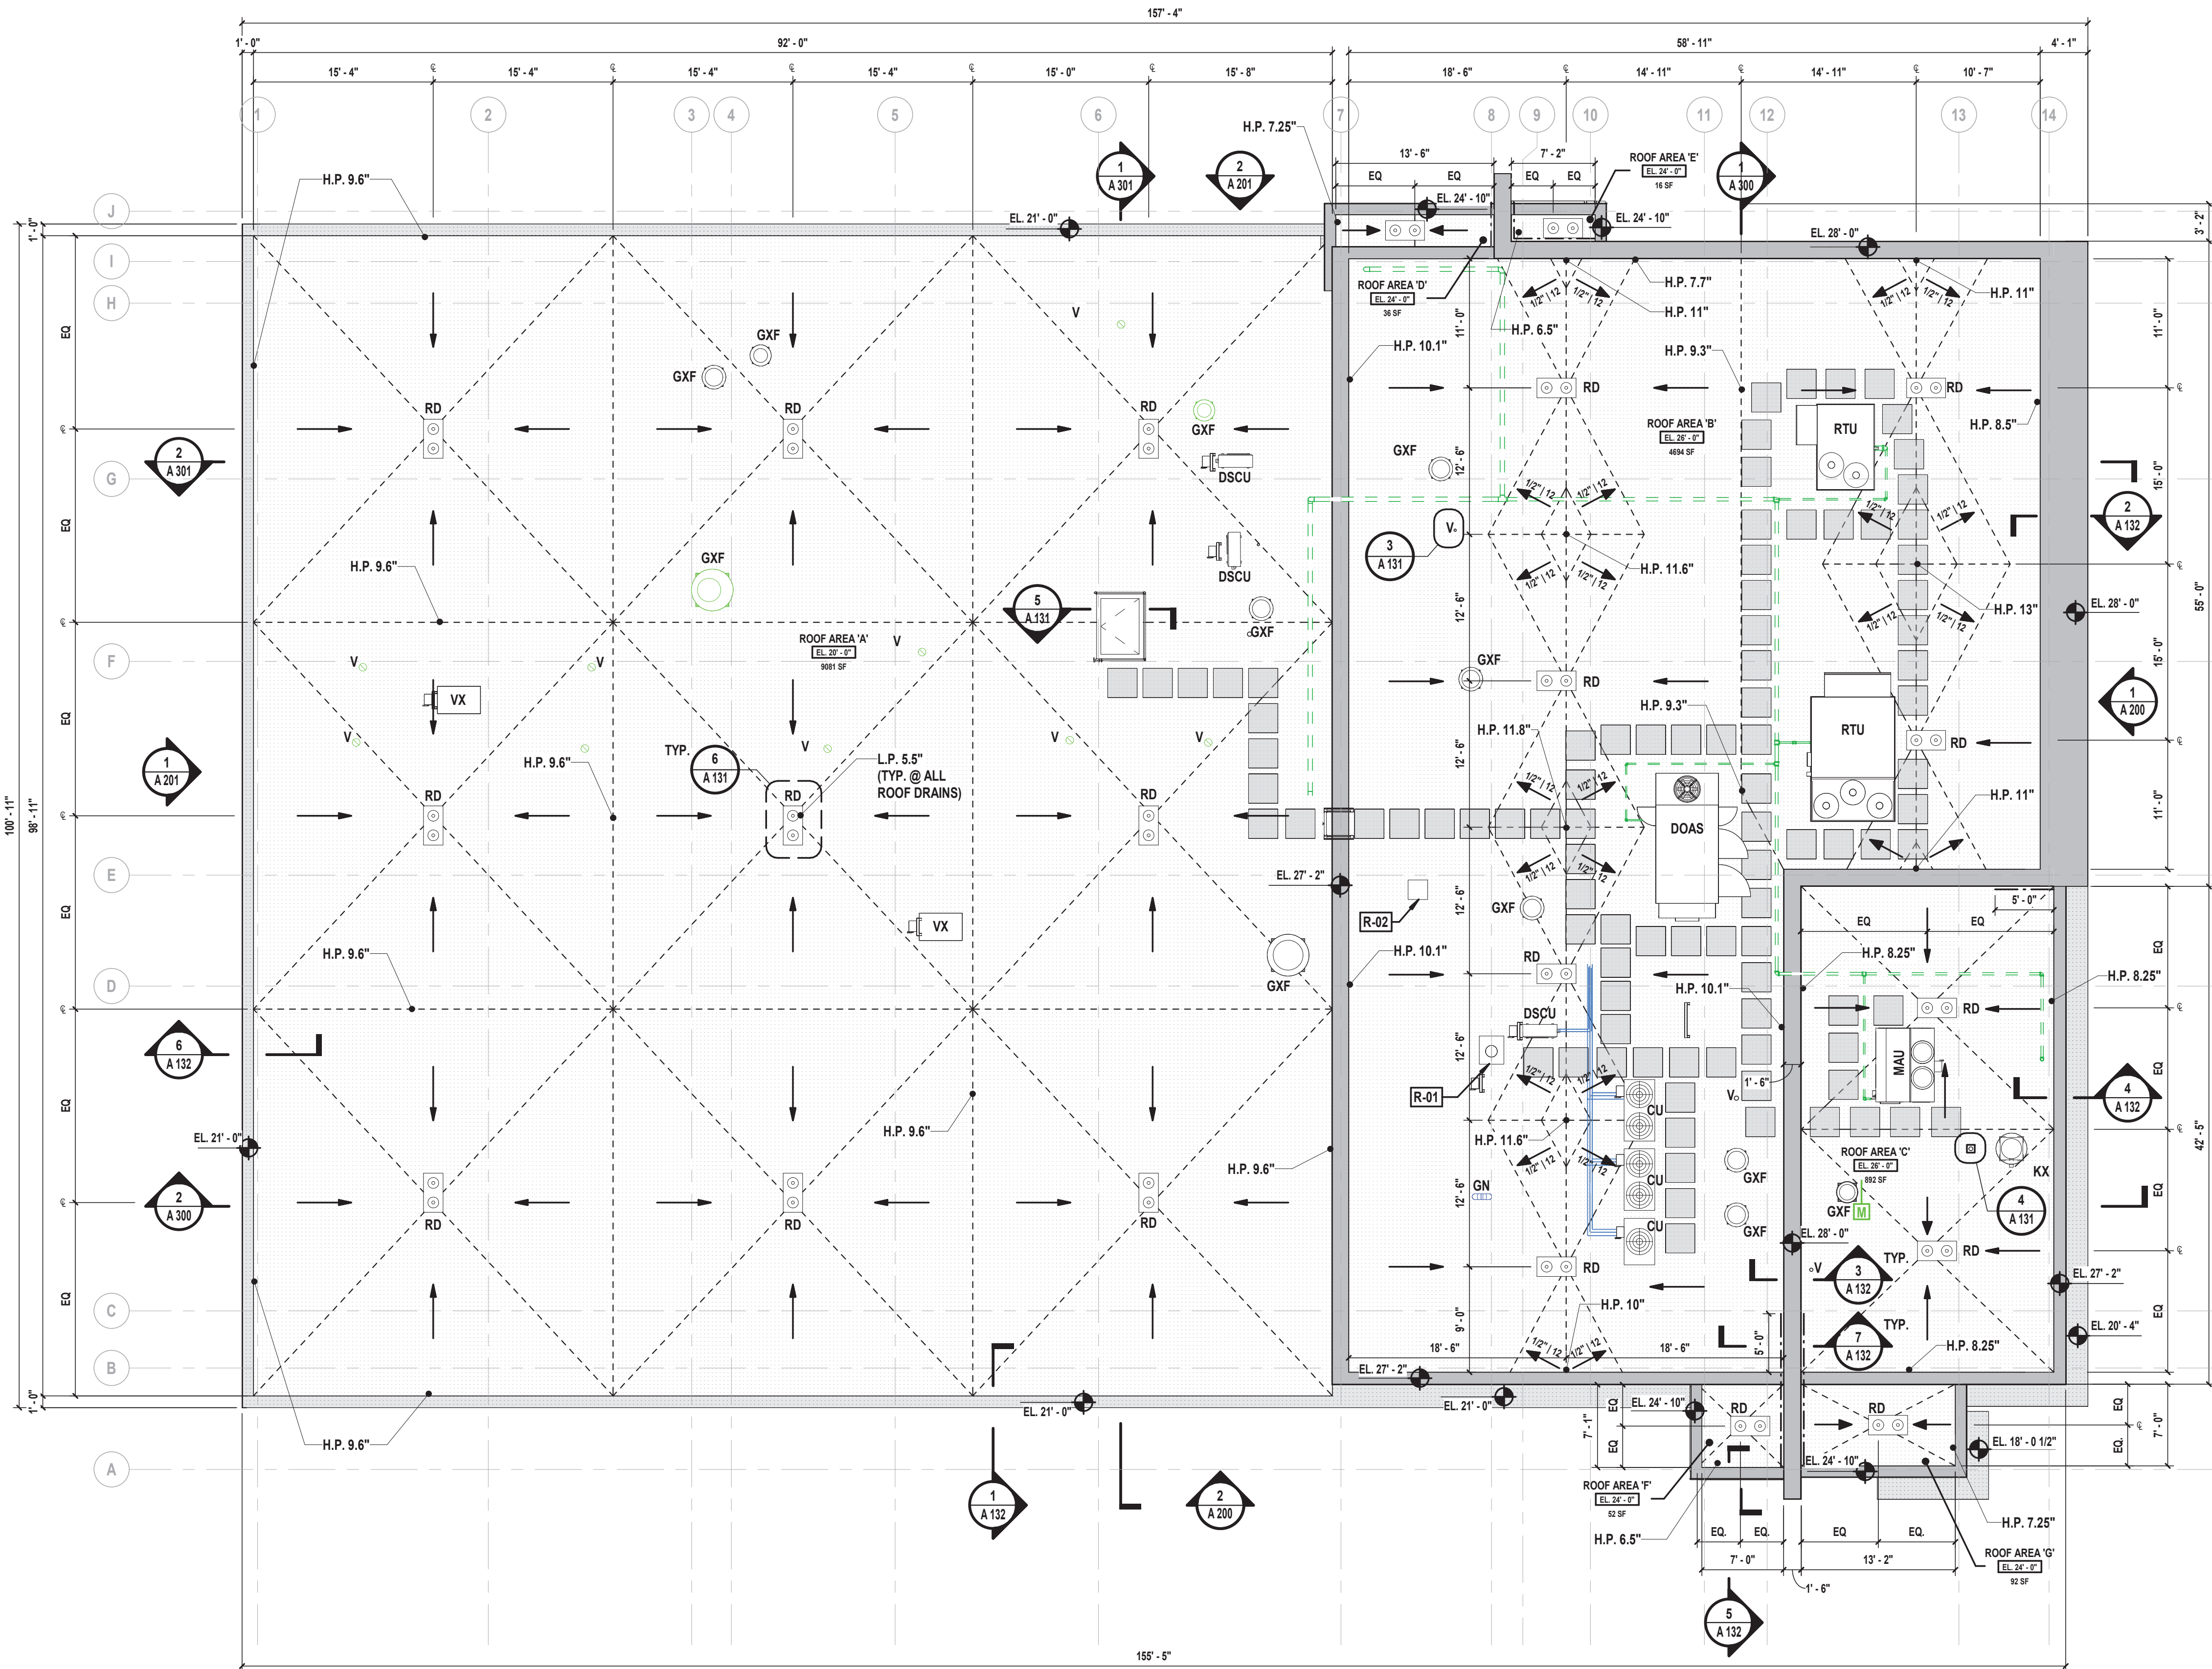

1 Roof Plan
SCALE: 1/8" = 1'-0"

ROOF KEYNOTE LEGEND

KEYNOTE	DESCRIPTION
R-01	POLE MOUNTED SIREN, PROVIDED BY OWNER, INSTALLED BY CONTRACT 'G'.
R-02	ROOF MOUNTED RADIO TOWER, PROVIDED BY OWNER, CONTRACT 'G' TO COORDINATE FINAL INSTALL.


GENERAL ROOFING NOTES

- THIS DRAWING SERVES AS A DEPICTION OF PRINCIPAL ROOFING ITEMS AND IS NOT A COMPLETE LIST OF EVERY ROOFING ITEM AND ACCESSORY. THIS DRAWING MUST BE COORDINATED WITH ALL OTHER DRAWINGS, ROOF DETAILS AND WITH ALL ITEMS SPECIFIED.
- CONTRACT 'G' IS RESPONSIBLE FOR PROVIDING ALL MATERIALS, LABOR, ROOFING ITEMS AND ACCESSORIES REQUIRED FOR A COMPLETE, WEATHER TIGHT AND WARRANTED INSTALLATION WHETHER OR NOT ITEMS MAY BE INDICATED ON THE DRAWINGS.
- COORDINATE THE WORK REQUIRED ON THIS DRAWING WITH ALL STRUCTURAL, CIVIL, ARCHITECTURAL, MECHANICAL, PLUMBING AND ELECTRICAL DRAWINGS, AND SPECIFICATIONS.
- CONTRACT 'G' TO COORDINATE WITH ALL OTHER CONTRACTS AND VERIFY EXACT LOCATIONS OF PENETRATIONS TO BE MADE IN ALL ROOFS AND ROOF ASSEMBLIES. PROVIDE PITCH POCKETS AS NEEDED.
- CONTRACT 'G' SHALL REVIEW, COORDINATE, AND INSTALL SLEEVES AND LOCATE ALL MECHANICAL PENETRATIONS REQUIRED TO ACCOMMODATE ALL WORK DETAILED OR SPECIFIED.
- CONTRACT 'G' IS RESPONSIBLE TO MAKE AND PROPERLY FLASH ALL ROOF PENETRATIONS. THE CONTRACTOR IS RESPONSIBLE FOR PROVIDING AND INSTALLING ALL FLASHING FOR ALL ROOF PENETRATIONS IN ACCORDANCE WITH ROOFING MANUFACTURER'S WARRANTY REQUIREMENTS AND SPECIFICATIONS U.N.O.
- CONTRACT 'G' SHALL PROVIDE ALL TEMPORARY ROOF FLASHING WORK AS REQUIRED. IT IS THE RESPONSIBILITY OF THE CONTRACTOR TO MAINTAIN A WEATHER TIGHT ROOF AT ALL TIMES.
- PROVIDE CRICKETS BEHIND ALL ROOFING ITEMS TO PROVIDE PITCH AND PREVENT PONDING. MODIFY AREAS OF WORK AS NECESSARY TO KEEP POSITIVE DRAINAGE.
- CONTRACT 'G' SHALL PROVIDE ADEQUATE TEMPORARY DRAINAGE FOR ALL PORTIONS OF THE ROOF, THROUGHOUT THE ENTIRE DURATION OF THE PROJECT.
- CONTRACTOR 'M' SHALL FURNISH SLEEVES AND LOCATE ALL MECHANICAL PENETRATIONS REQUIRED TO ACCOMMODATE ALL WORK DETAILED OR SPECIFIED.
- CONTRACT 'M' SHALL FURNISH ALL CURBS FOR EXHAUST FANS, AND HEATING/COOLING UNITS TO CONTRACT 'G' FOR INSTALLATION.
- ROOFING INSTALLATION SHALL INCLUDE PROVIDING ALL PENETRATIONS FOR ALL ITEMS NECESSARY, WHETHER SHOWN OR NOT, AND SHALL ALSO INCLUDE TERMINATIONS AND FLASHING AS REQUIRED TO PROVIDE WARRANTED SYSTEMS IN ACCORDANCE WITH THE SPECIFIED WARRANTY REQUIREMENTS.
- CONTRACT 'G' IS RESPONSIBLE FOR ALL DAMAGES TO THE INTERIOR AND EXTERIOR OF THE BUILDING THAT RESULTED FROM AND DURING ROOFING INSTALLATION, INCLUDING BUT NOT LIMITED TO, ADHESIVE DRIPPINGS, WATER LEAKS, ETC.
- CONTRACT 'G' SHALL PROVIDE SNOW GUARDS AT ALL LOCATIONS WHERE ENTRANCES OR PEDESTRIAN TRAFFIC ARE LOCATED BELOW.


ROOFING SYMBOL LEGEND

	EPDM ROOFING SYSTEM
	WALKWAY PADS - FINAL LOCATION TO BE DETERMINED IN FIELD WITH OWNER/ARCHITECT
	ROOF COPING
	METAL WALL CLADDING OVER PARAPET WALL, REFER TO ROOFING DETAILS FOR ADDITIONAL INFORMATION
L.P. / H.P.	LOW POINT / HIGH POINT OF ROOF INSULATION
	ROOF PITCH - 1/4" PER FOOT, MIN., U.N.O.
	VENT - SEE 'M' AND 'P' DRAWINGS
	ROOF TIE OFF
	ROOF HATCH
	ROOF DRAIN (L.P.) W/ PRIMARY AND OVERFLOW - COORDINATE WITH 'P' DRAWINGS
	CONDENSING UNIT, SIZE AND SHAPE VARY - COORDINATE WITH 'M' DRAWINGS
	AIR-COOLED CONDENSING UNITS. CONTRACT 'M' TO PROVIDE METAL CURBS FOR INSTALLATION BY CONTRACT 'G' - COORDINATE WITH 'M' DRAWINGS
	GENERAL, VEHICLE & KITCHEN EXHAUST FANS, SIZE AND SHAPE VARY. CONTRACT 'M' TO PROVIDE METAL CURBS FOR INSTALLATION BY CONTRACT 'G' - COORDINATE WITH 'M' DRAWINGS
	MAKE UP AIR UNIT - COORDINATE WITH 'M' DRAWINGS
	DEDICATED OUTDOOR AIR SYSTEM, SIZE AND SHAPE VARY - COORDINATE WITH 'M' DRAWINGS
	GENERAL EXHAUST FAN, VEHICLE EXHAUST & KITCHEN EXHAUST, SIZE AND SHAPE VARY - COORDINATE WITH 'M' DRAWINGS
	STAINLESS STEEL CHANNEL SUPPORT, SIZE AND SHAPE VARY - COORDINATE WITH 'E' DRAWINGS


MARK	DATE	DESCRIPTION

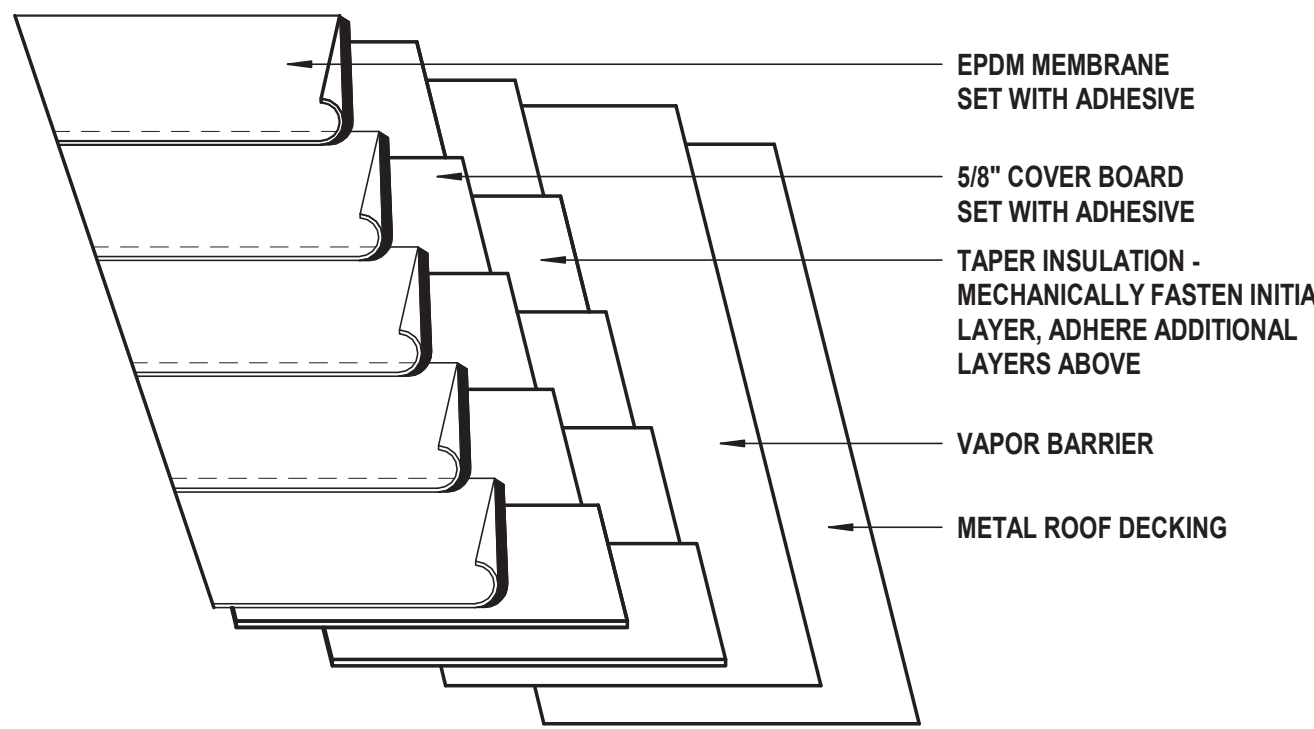


1 Typical EPDM Roofing System
SCALE: 1 1/2" = 1'-0"

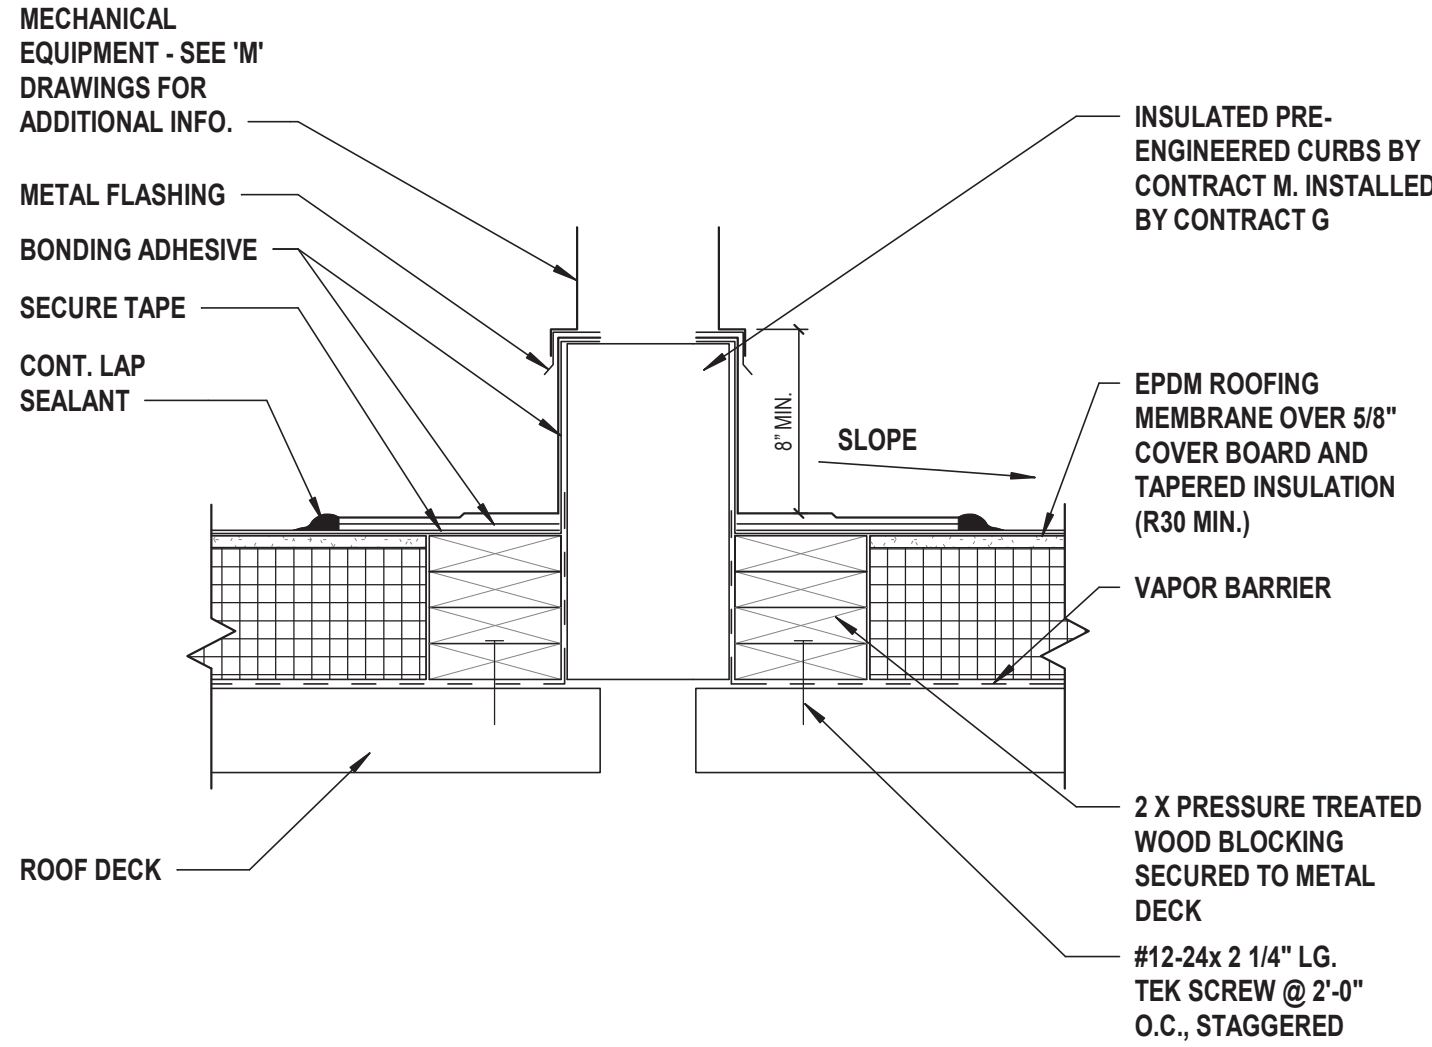


2 Typical Roof Curb Detail (EPDM Roof)
SCALE: 1 1/2" = 1'-0"

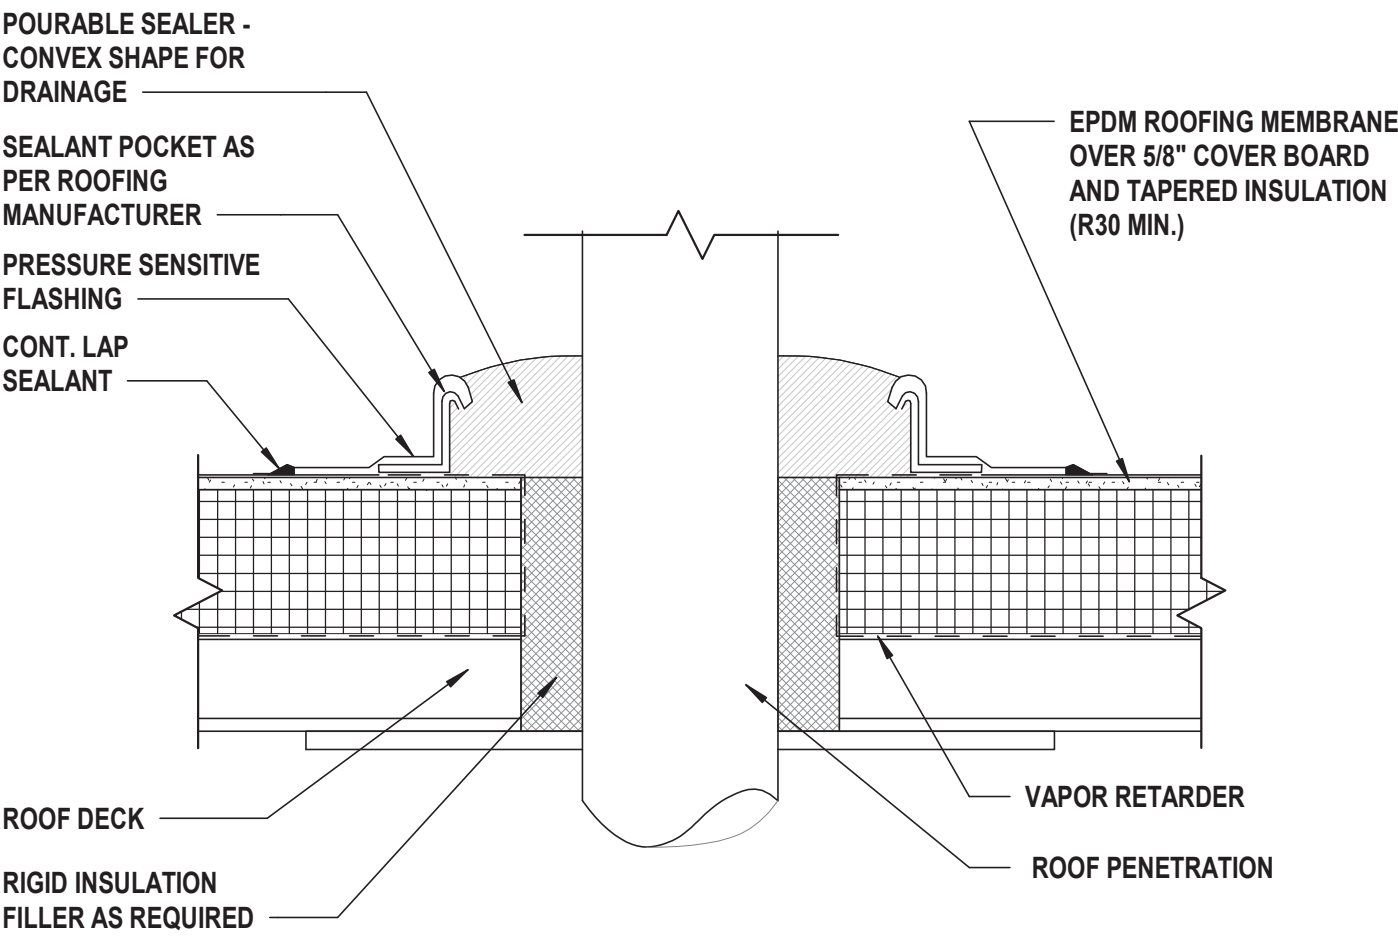


3 Typical Pitch Pocket Detail (EPDM Roof)
SCALE: 1 1/2" = 1'-0"

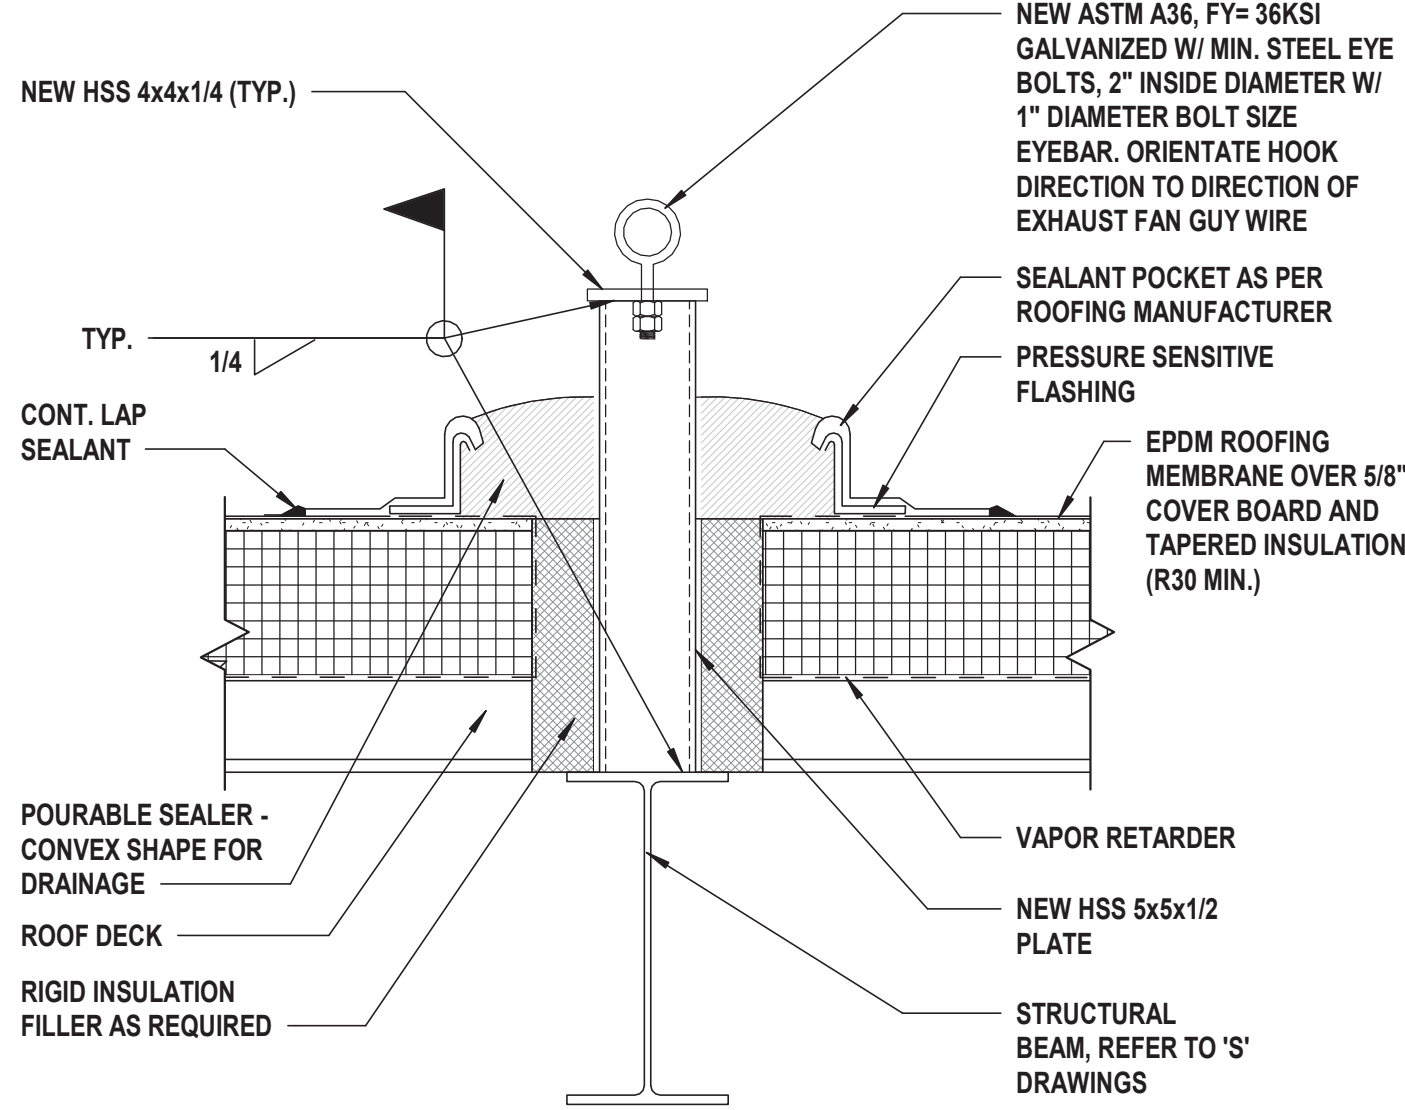


4 Tieoff Detail
SCALE: 1 1/2" = 1'-0"

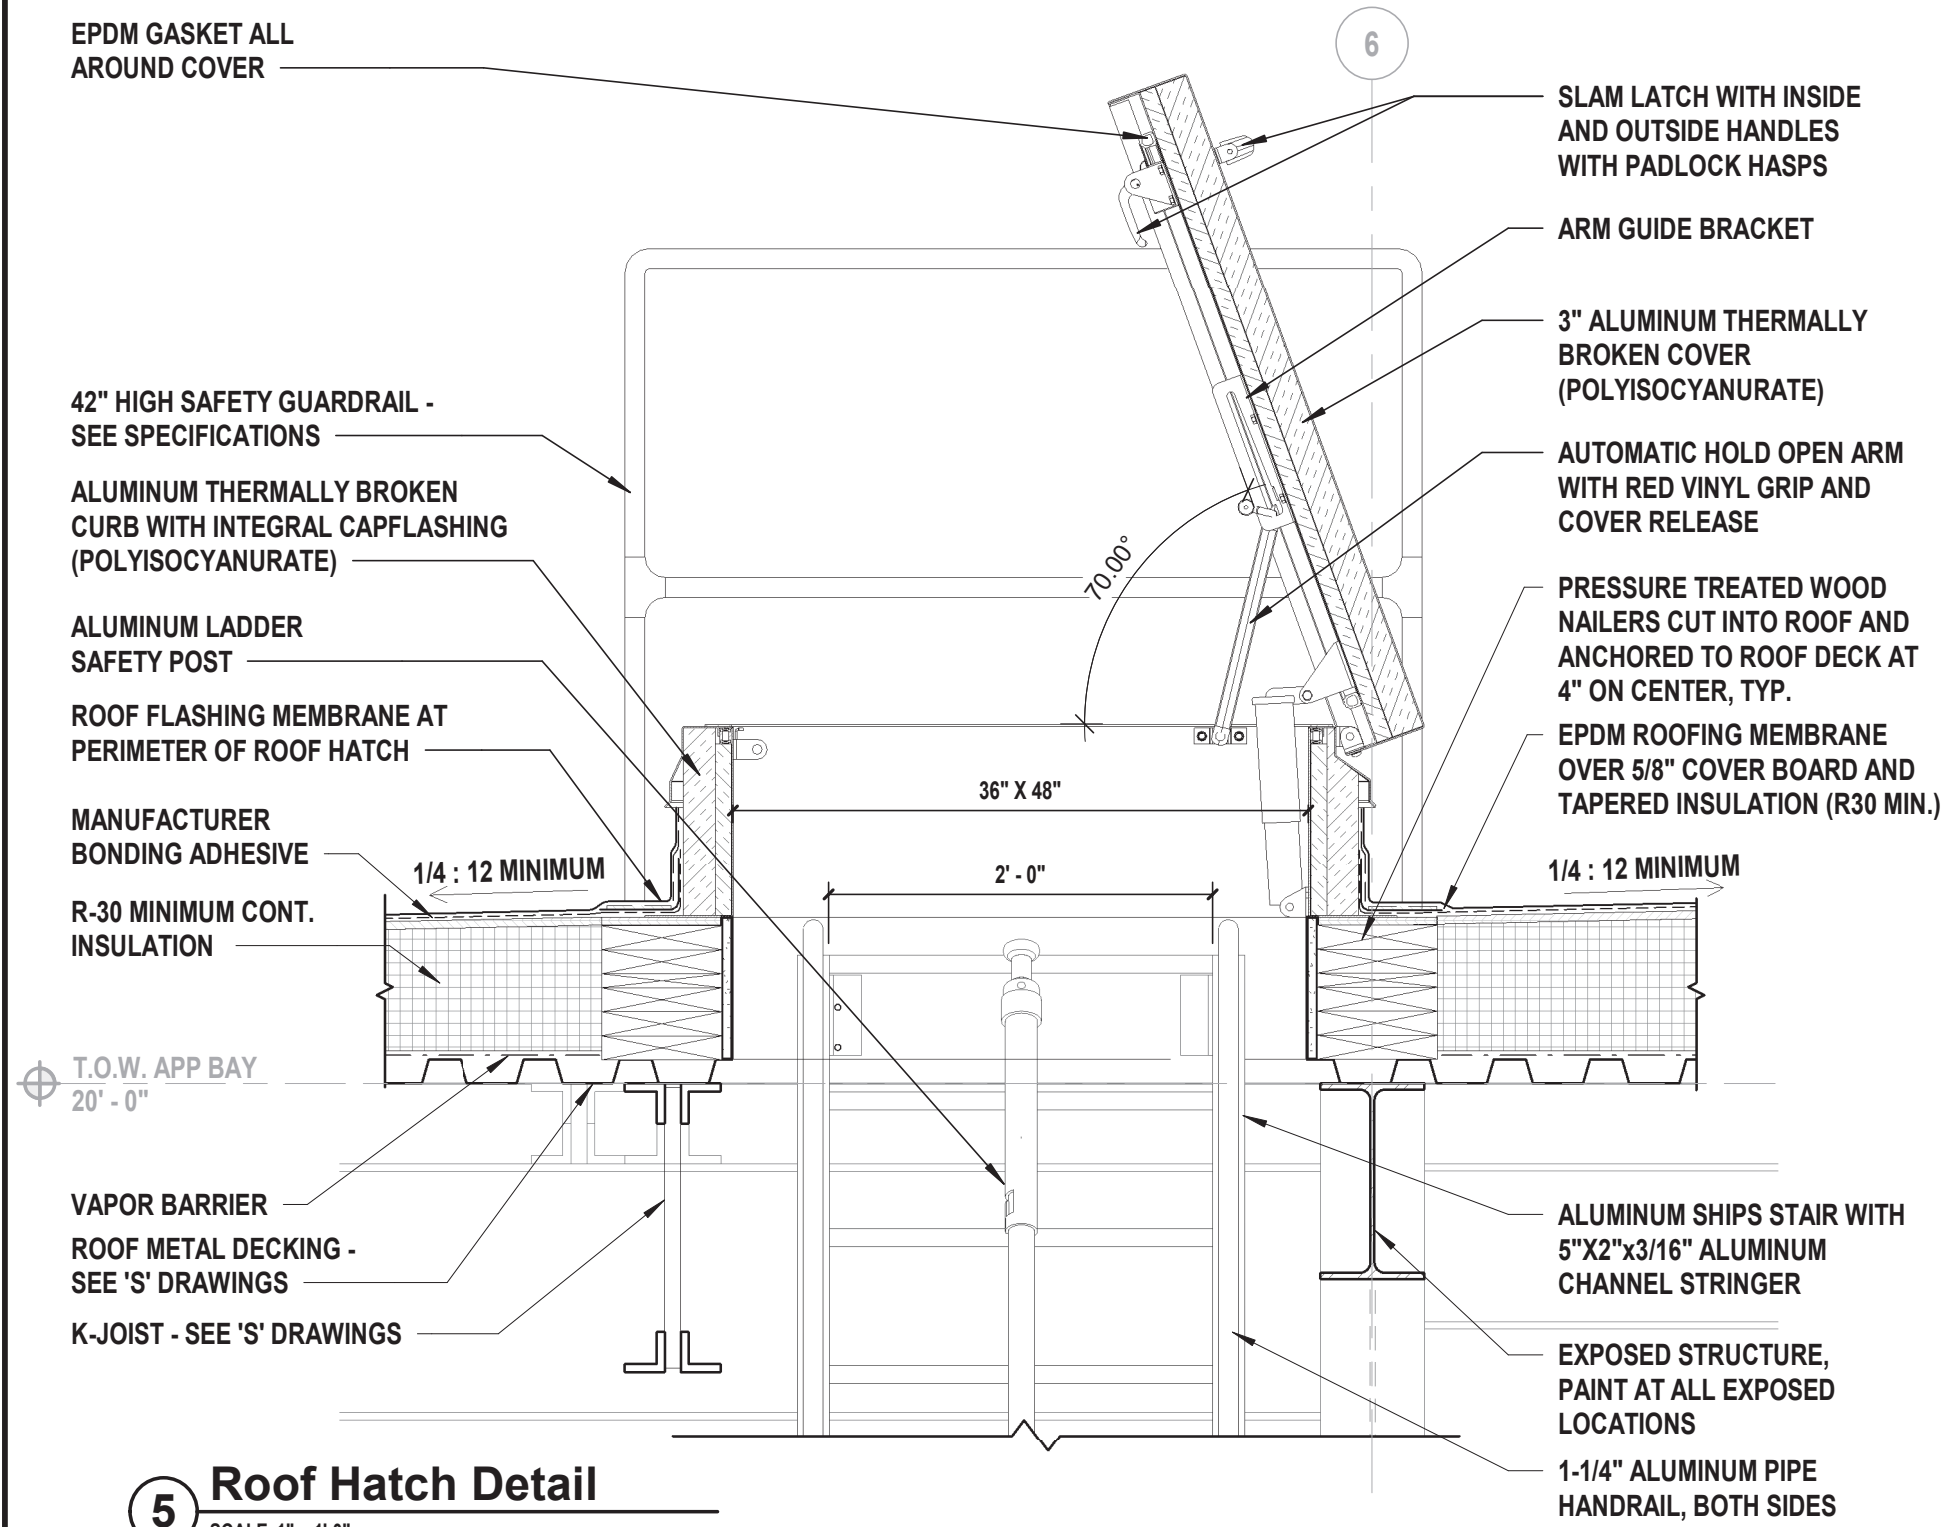

5 Roof Hatch Detail
SCALE: 1" = 1'-0"

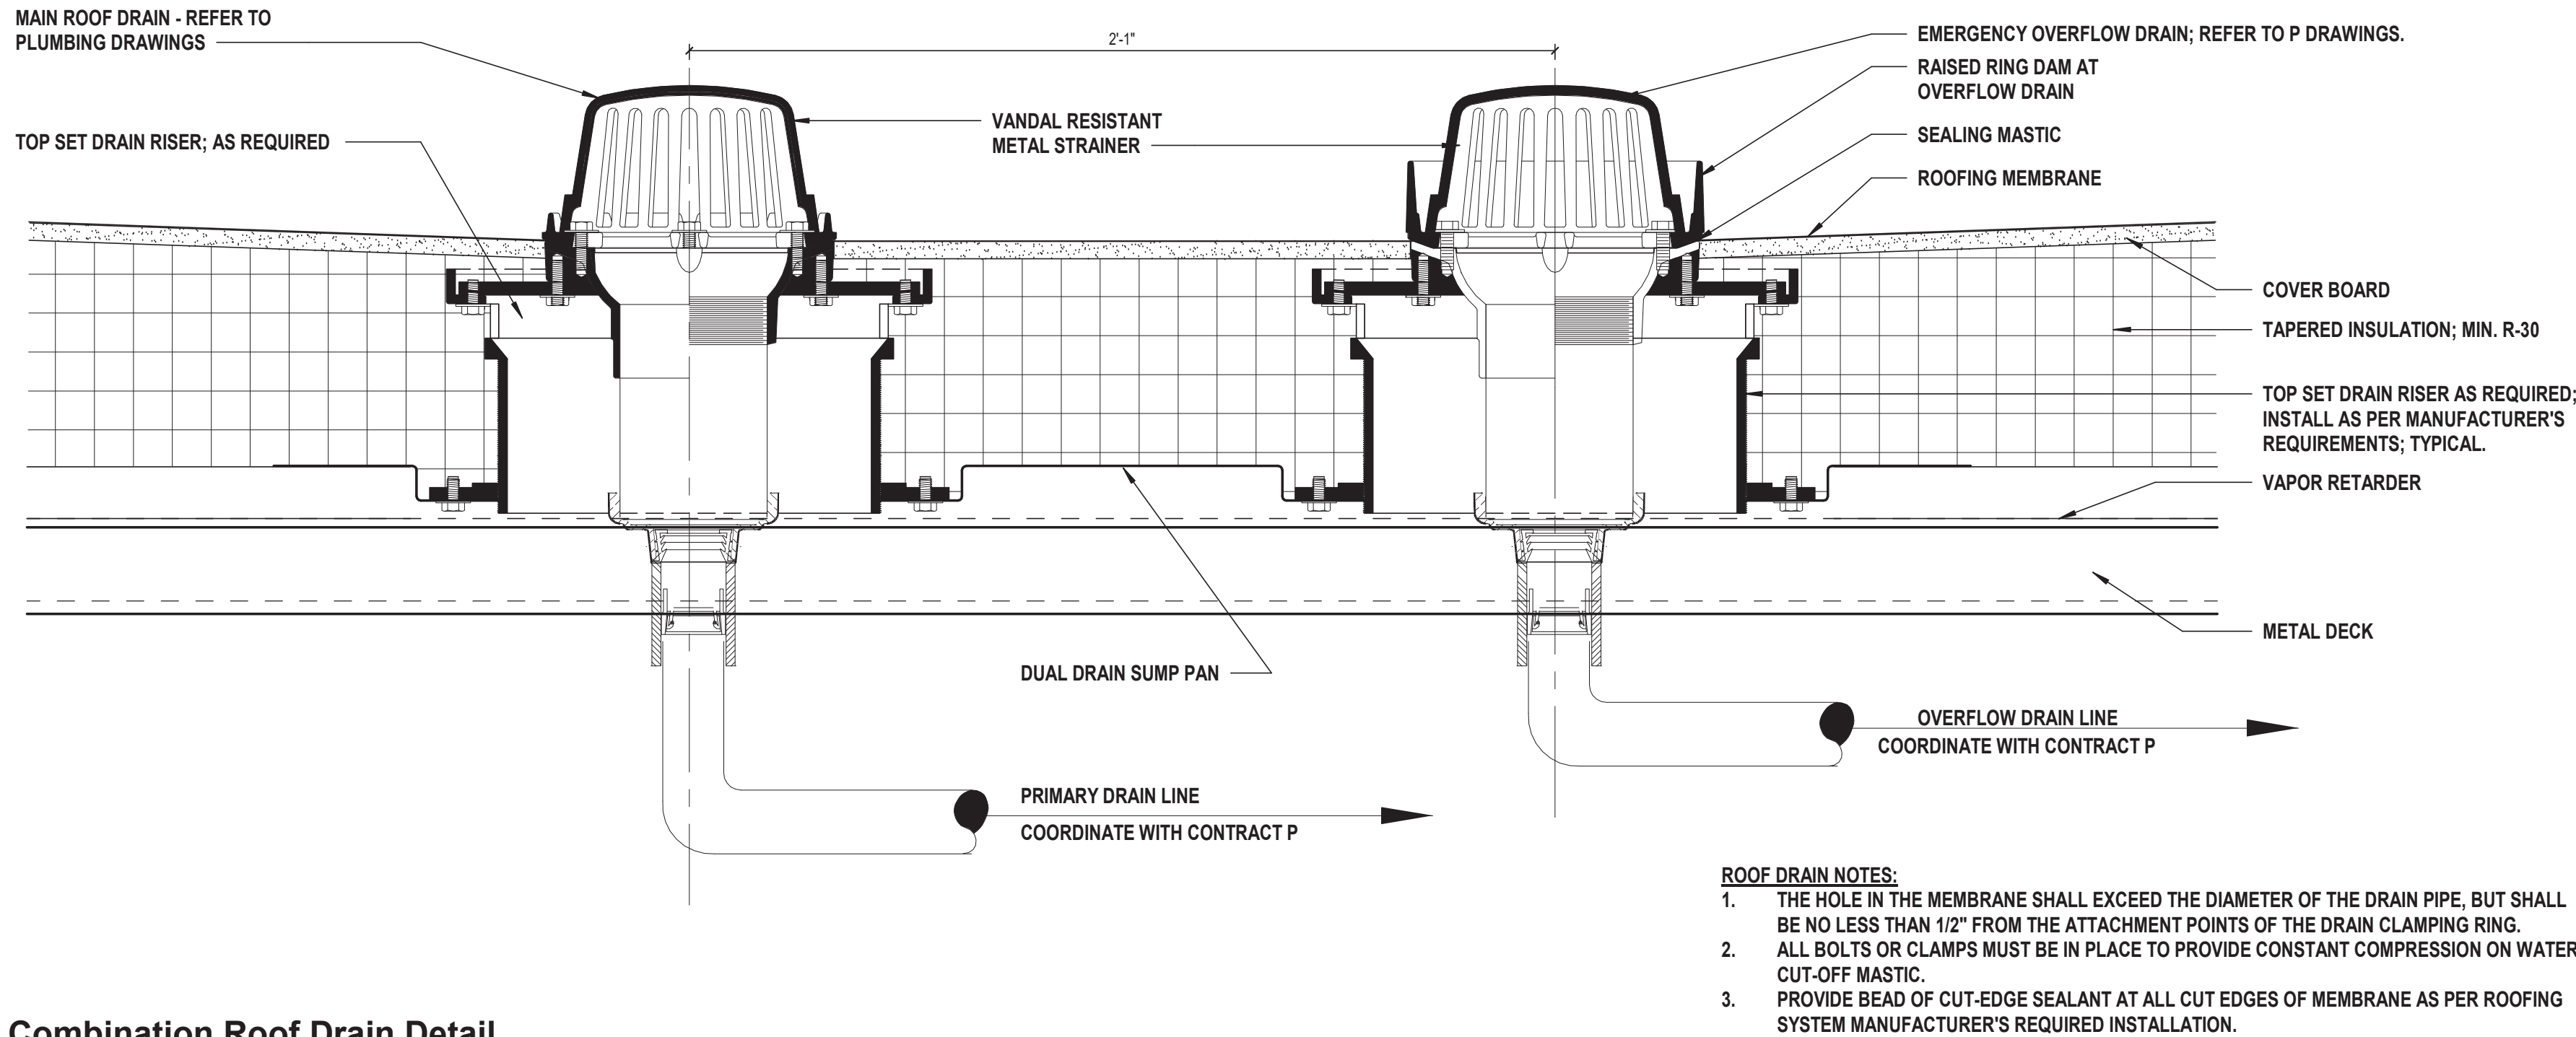


6 Combination Roof Drain Detail
SCALE: 3" = 1'-0"

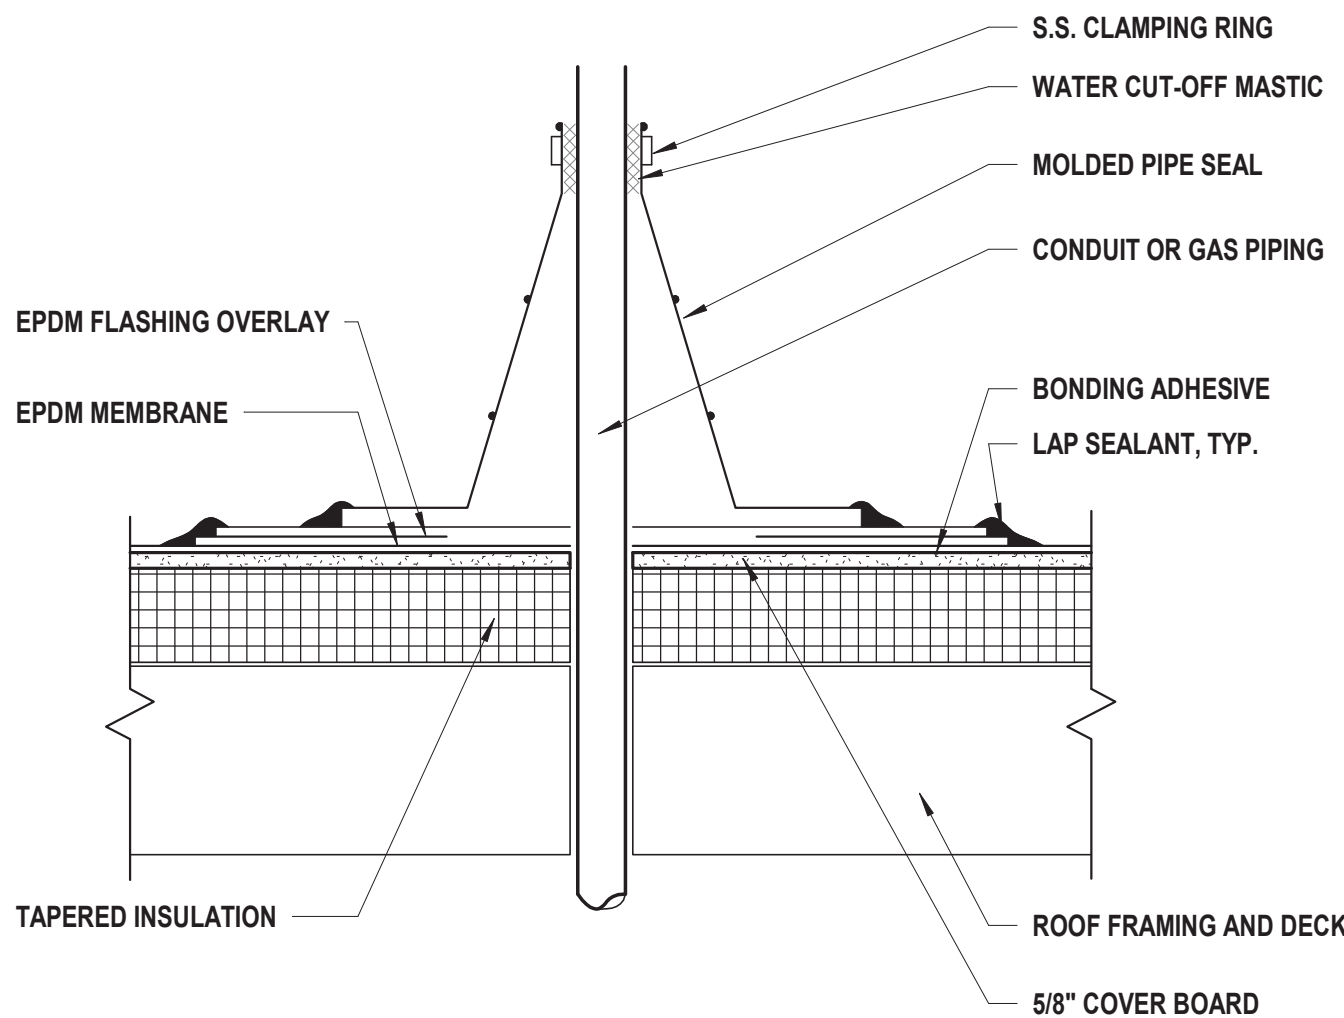

7 Typical Pipe Penetration Detail
SCALE: 1 1/2" = 1'-0"

CONSULTANTS:

MARK	DATE	DESCRIPTION

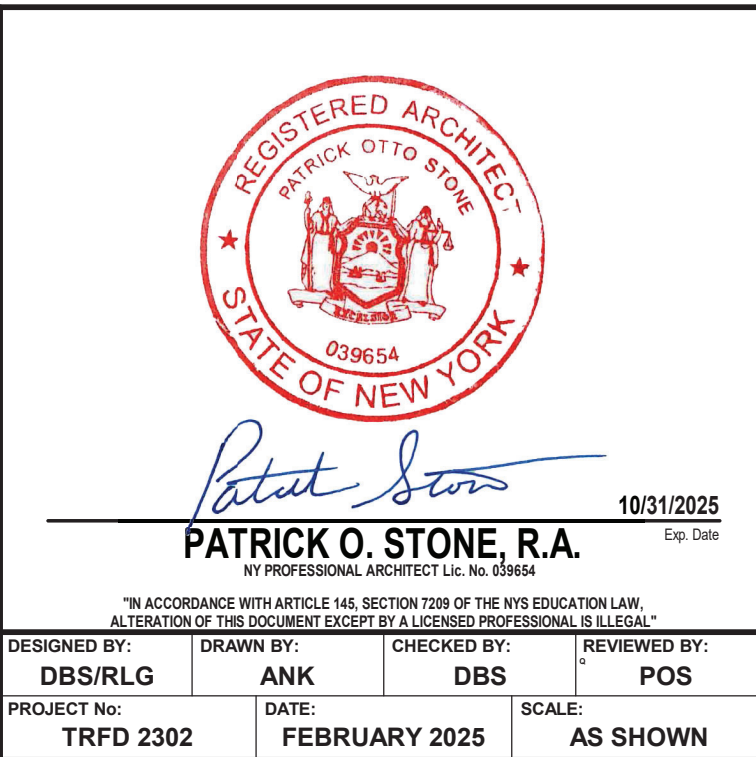

CLIENT

**THIELLS
ROSEVILLE FIRE
DISTRICT**

**NEW 26-100 FIRE
HEADQUARTERS**

**65 W RAMAPO ROAD
GARNERVILLE, NY 10923**

CONTRACT

**CONTRACT G
GENERAL CONSTRUCTION**

STATUS

FINAL BID DOCUMENT


SHEET TITLE

ROOFING DETAILS


DRAWING No.

A 131.00


C:\Users\skelad\Documents\TRED2302_Central23_A_A\skelad.rvt 2/25/2025 4:08:47 PM

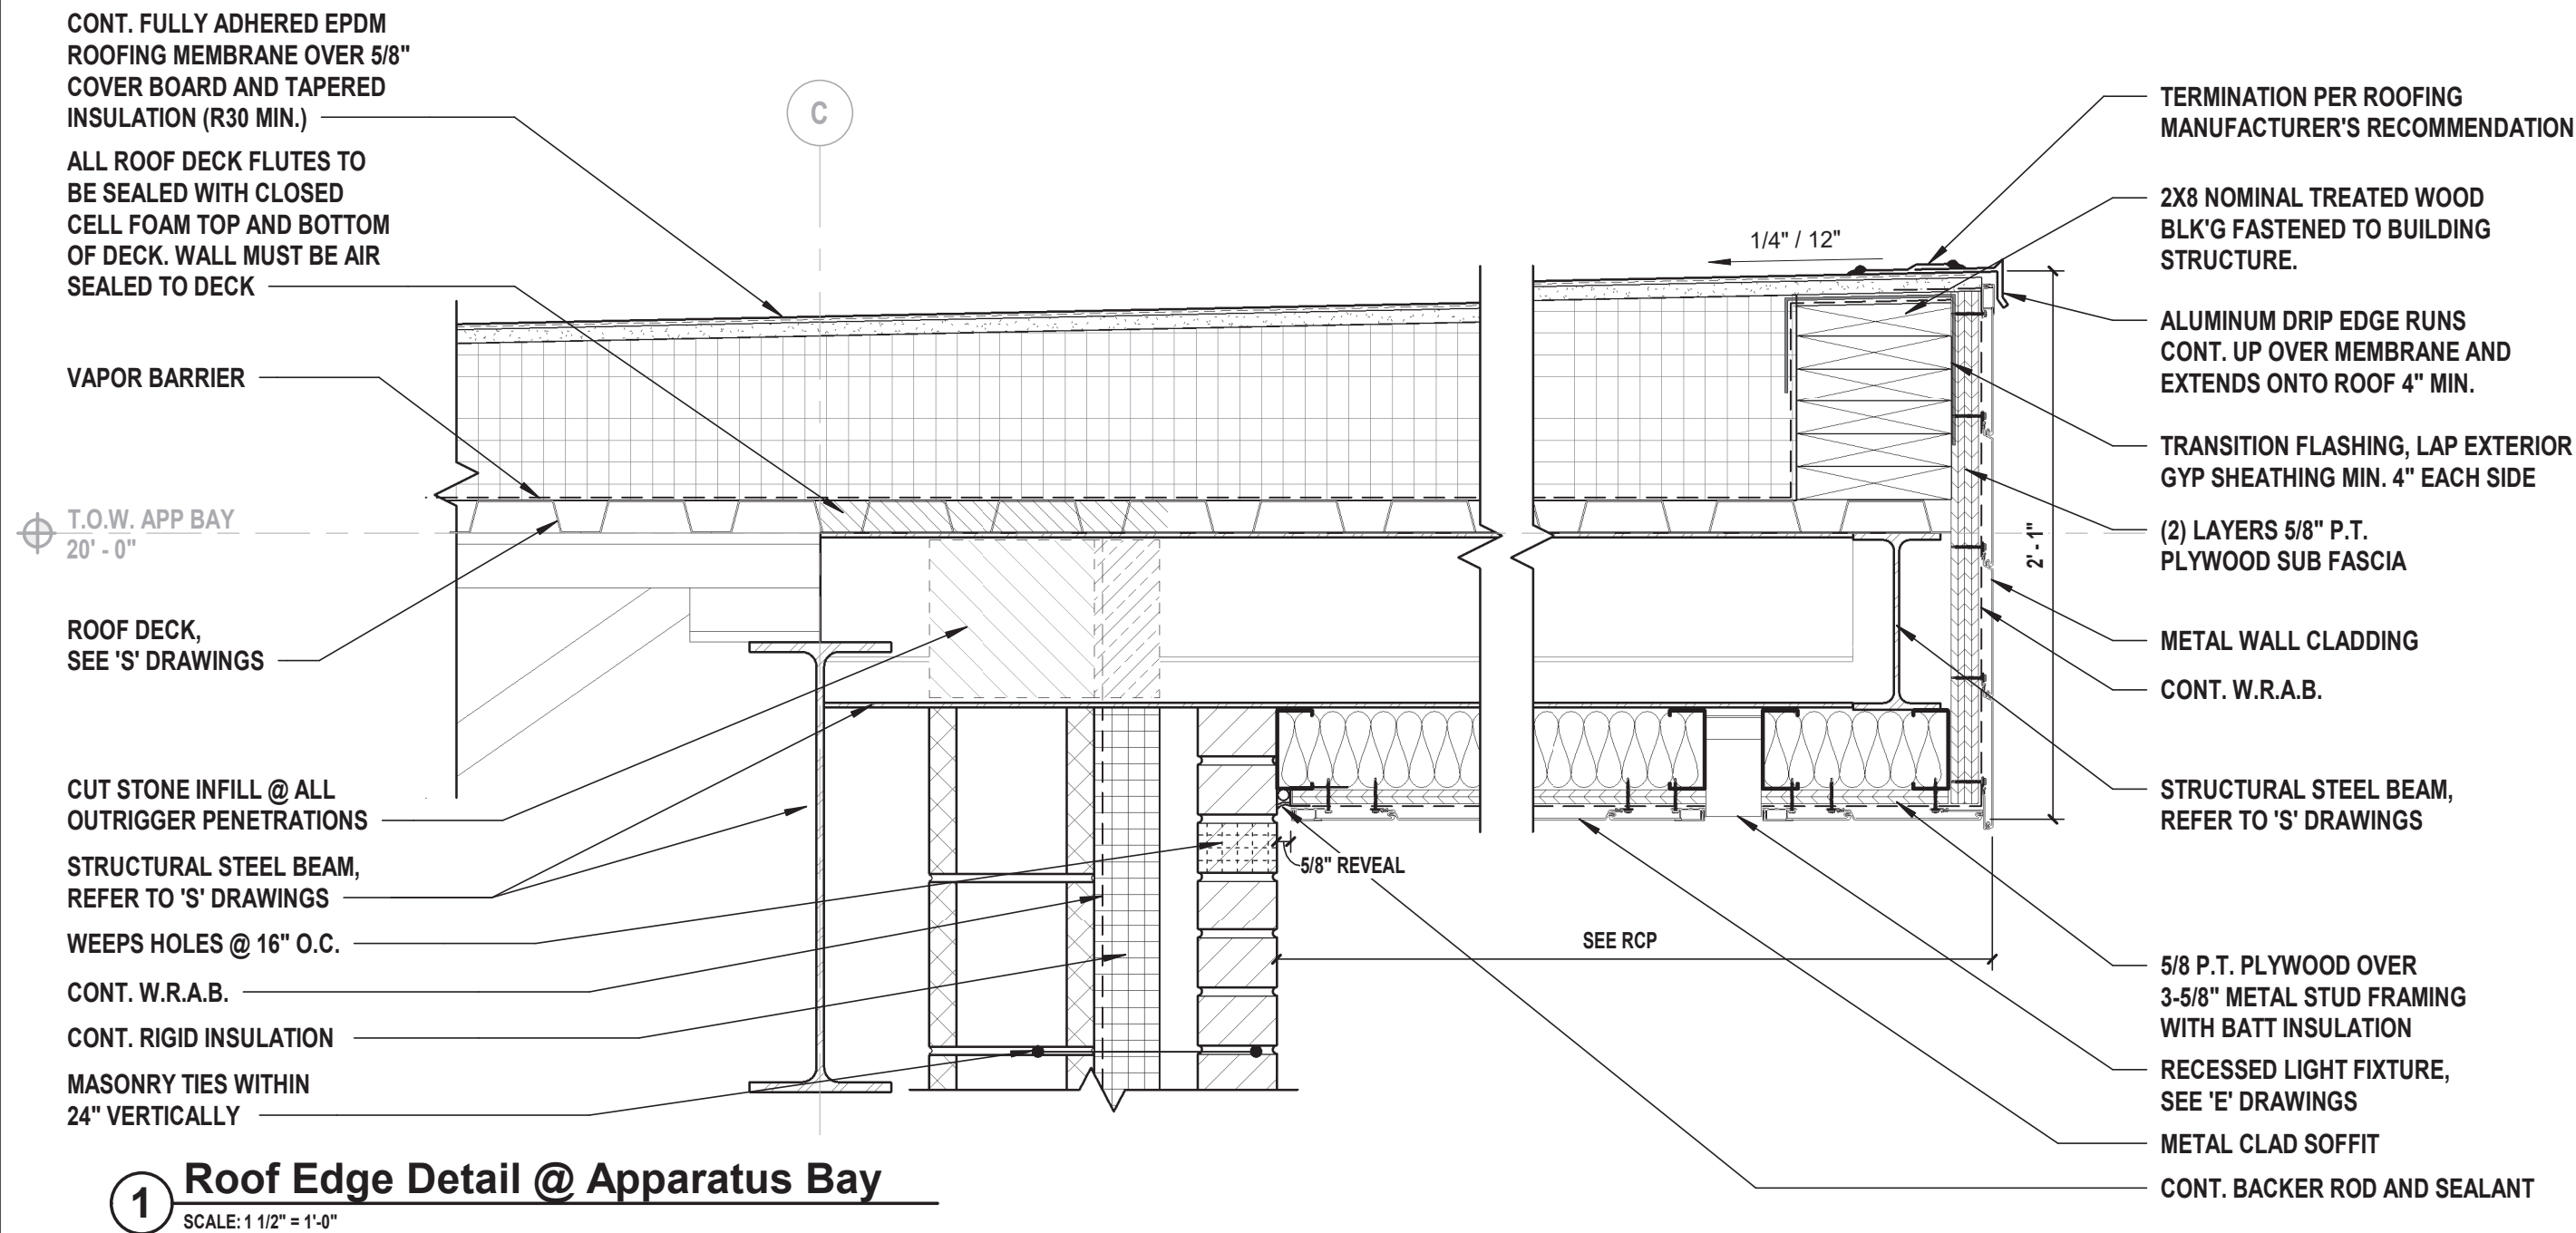


1 Roof Edge Detail @ Apparatus Bay
SCALE: 1 1/2" = 1'-0"

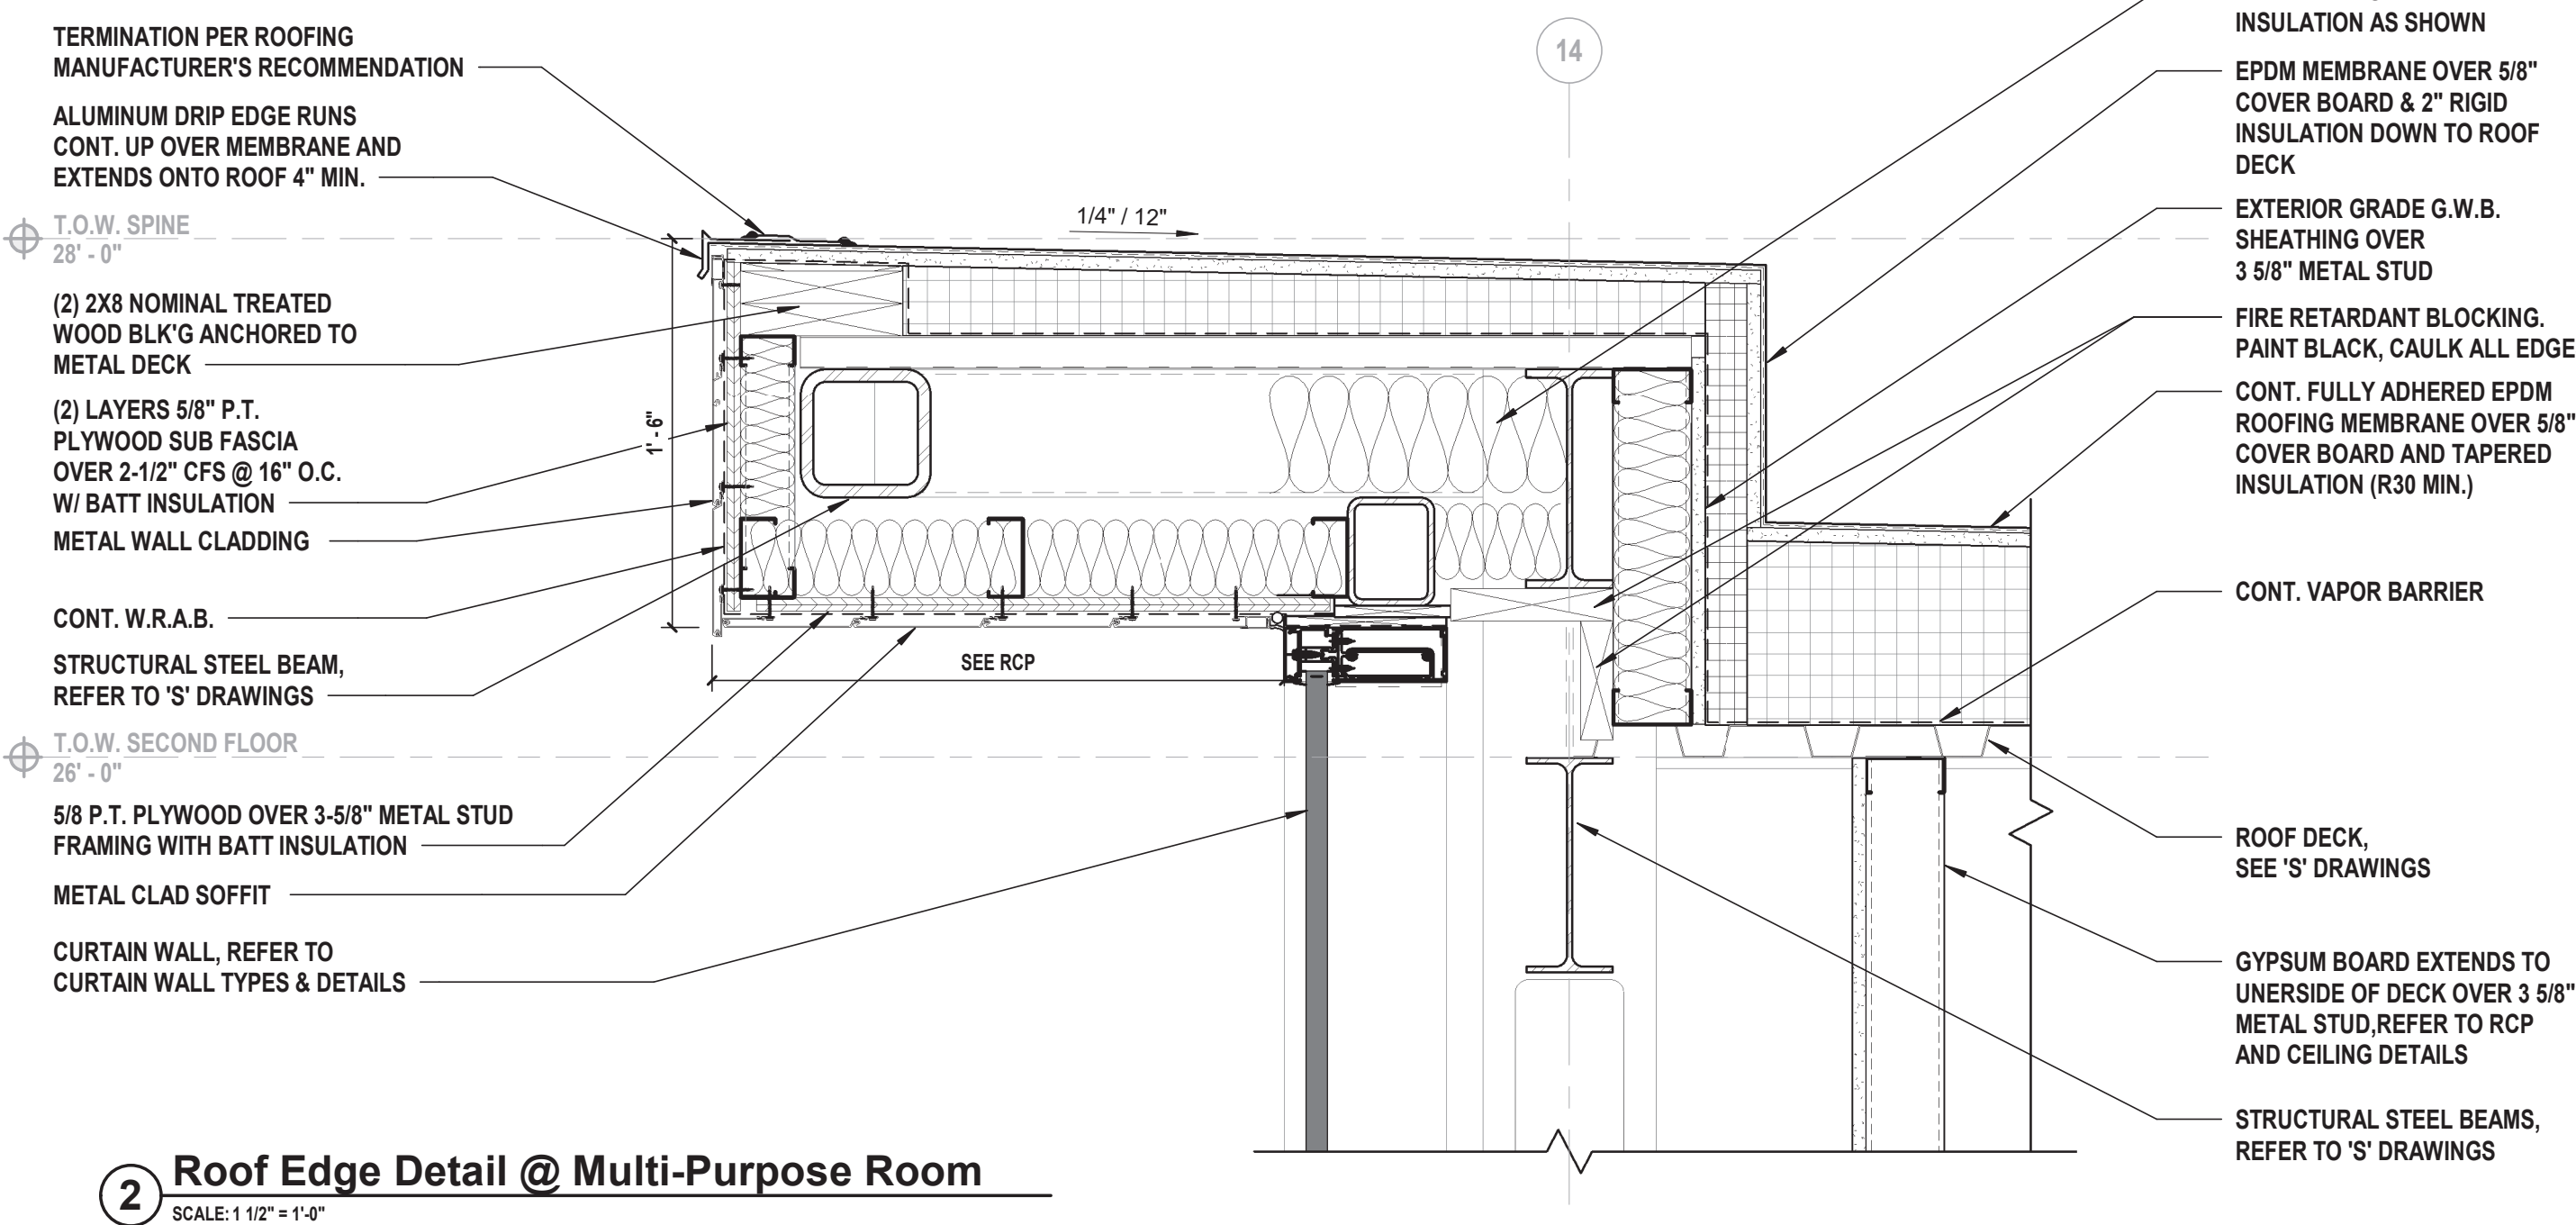


2 Roof Edge Detail @ Multi-Purpose Room
SCALE: 1 1/2" = 1'-0"

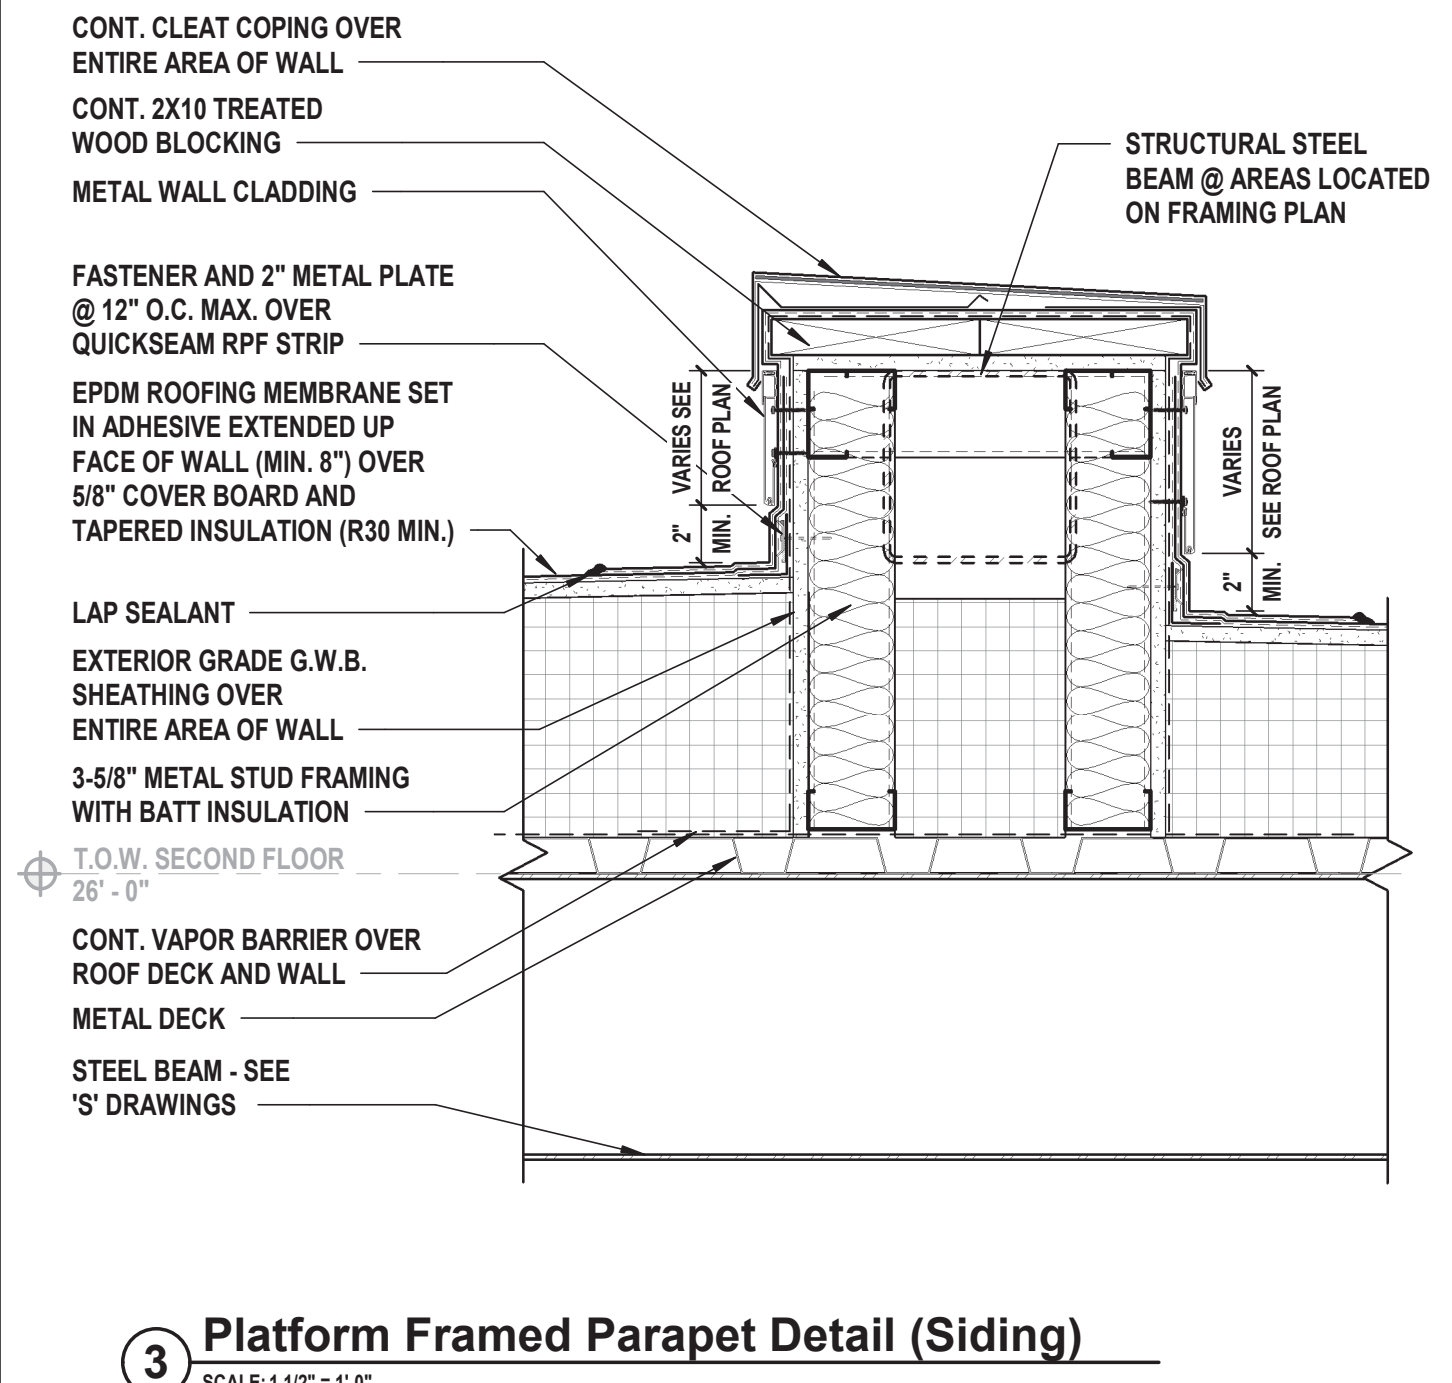


3 Platform Framed Parapet Detail (Siding)
SCALE: 1 1/2" = 1'-0"

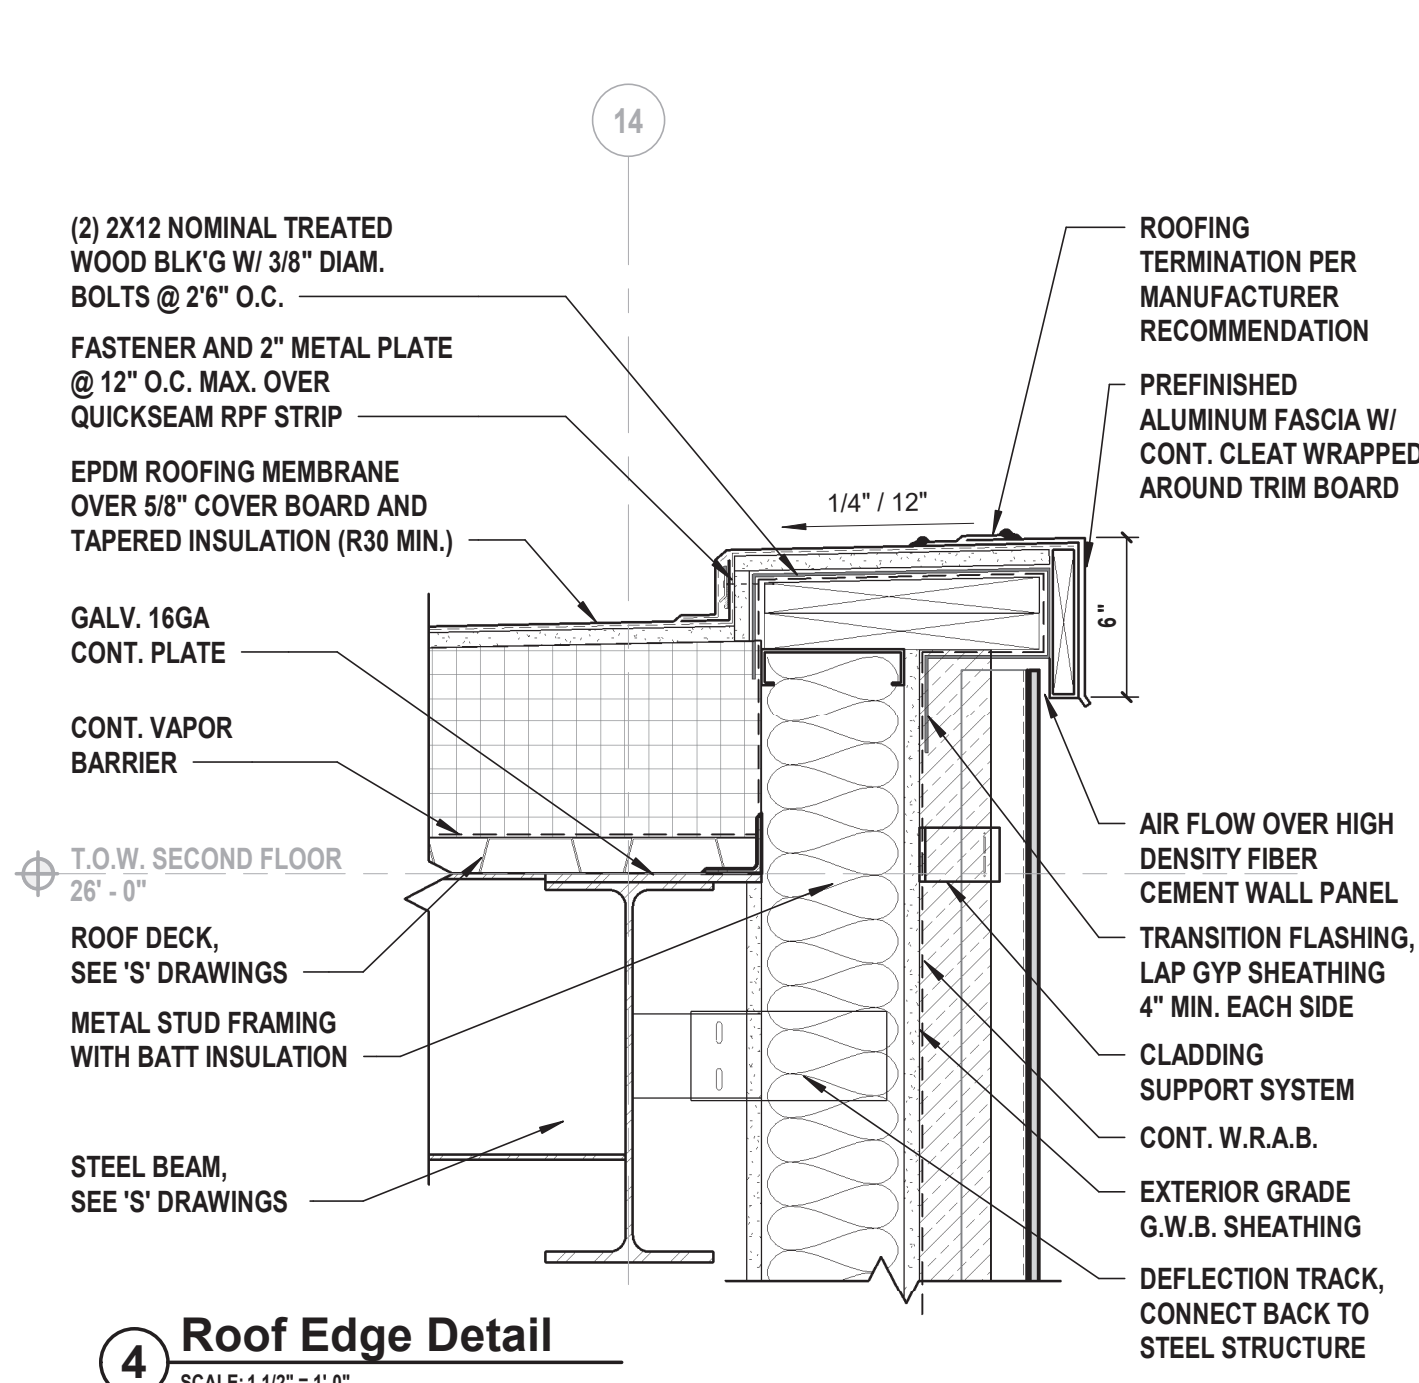


4 Roof Edge Detail
SCALE: 1 1/2" = 1'-0"

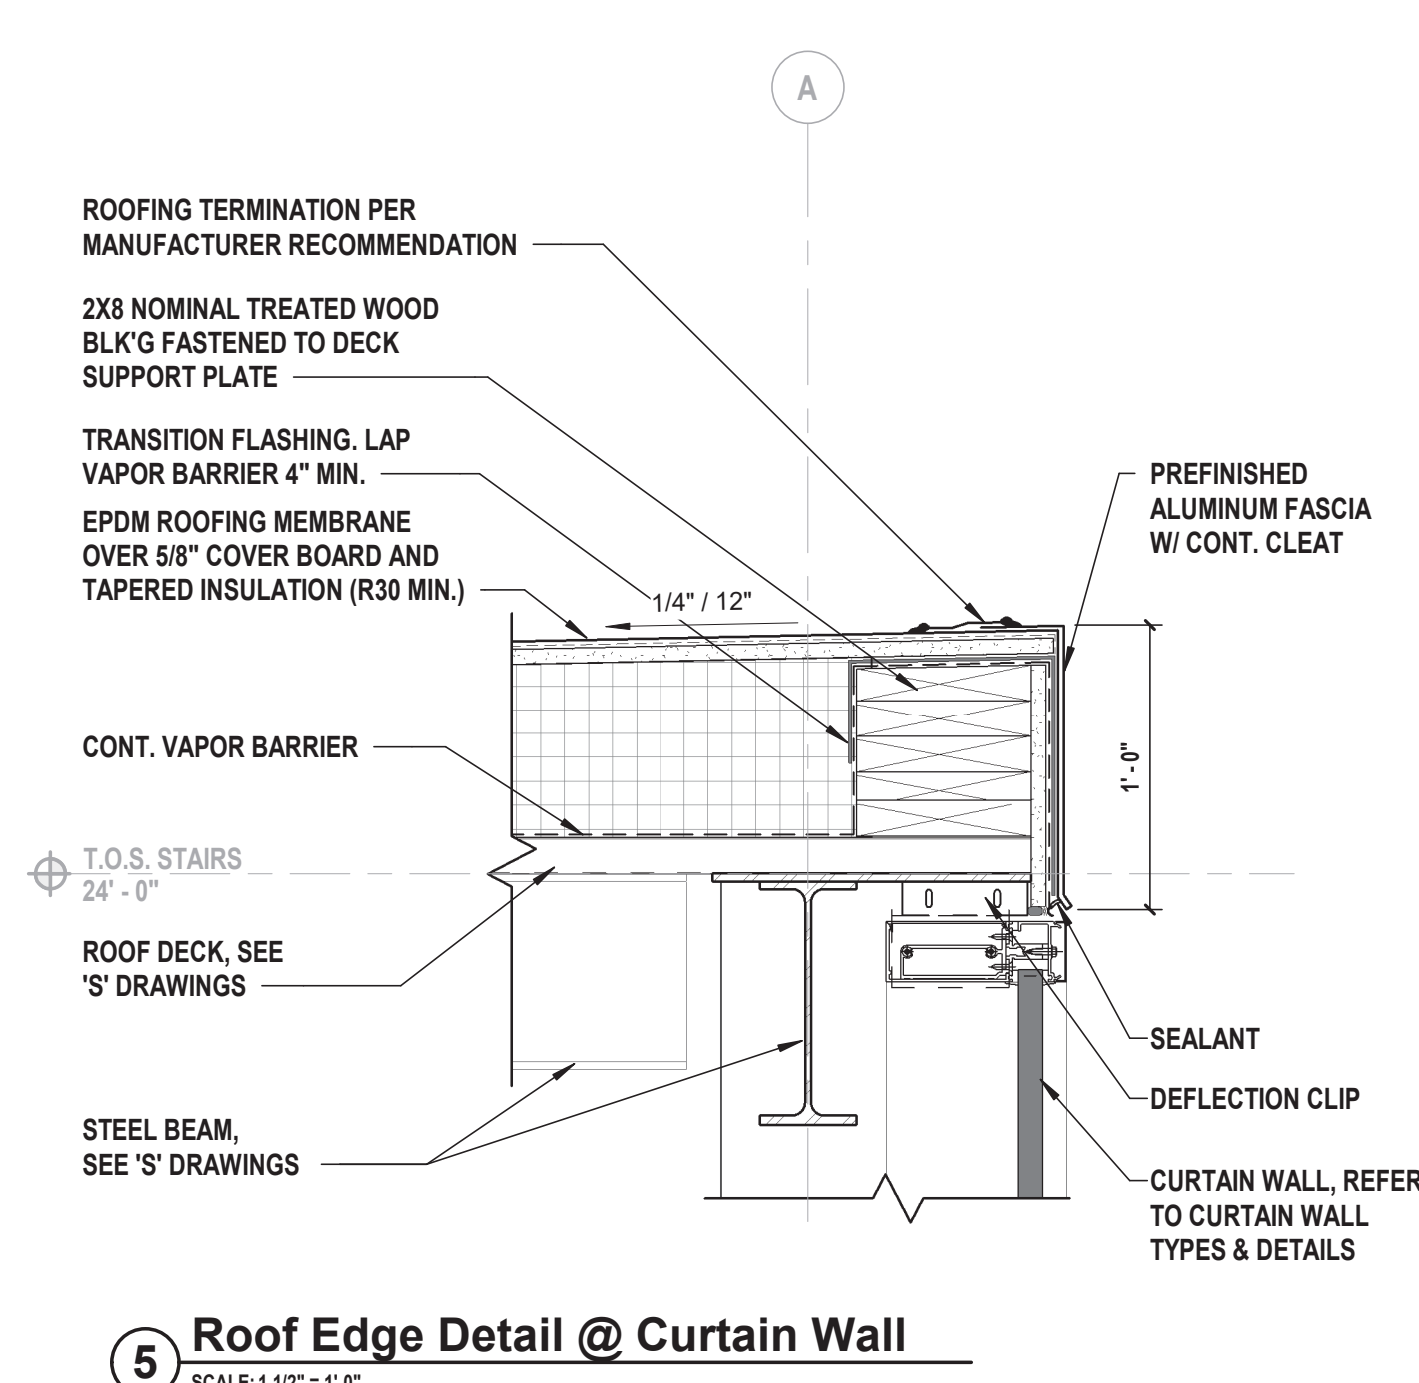

5 Roof Edge Detail @ Curtain Wall
SCALE: 1 1/2" = 1'-0"

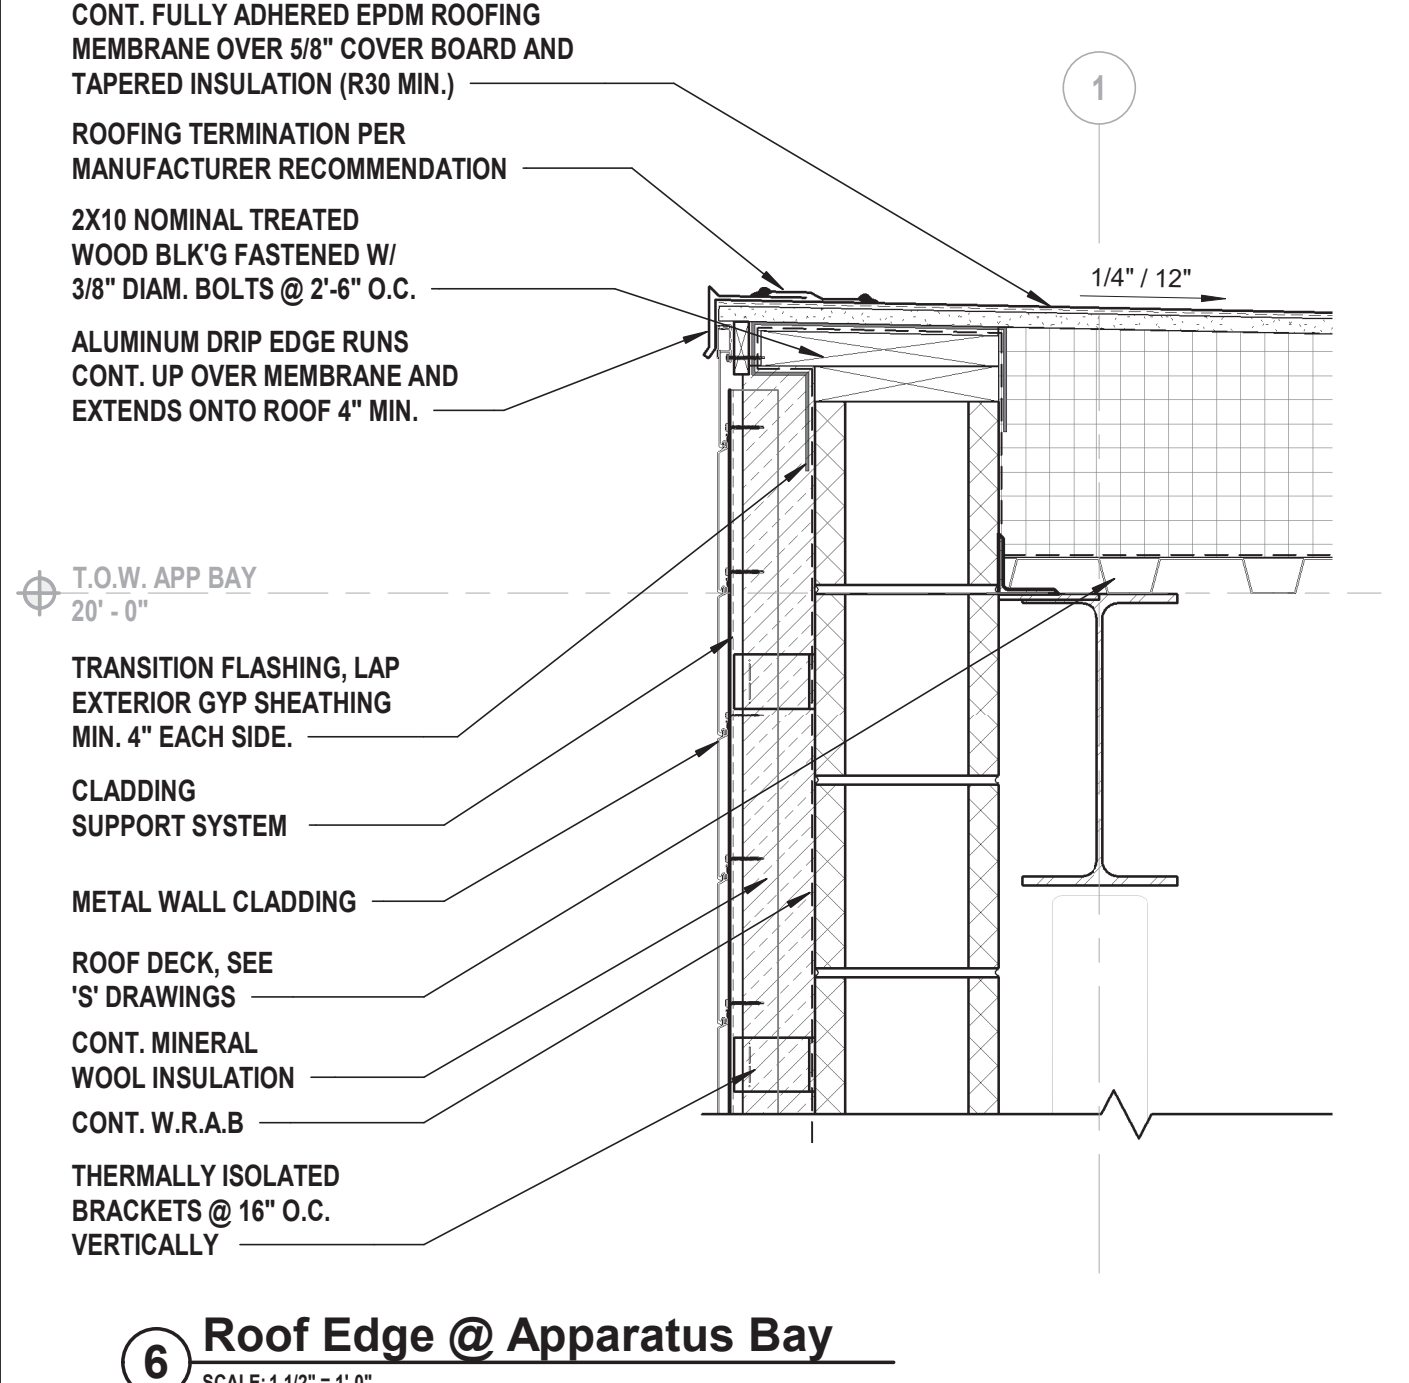

6 Roof Edge @ Apparatus Bay
SCALE: 1 1/2" = 1'-0"

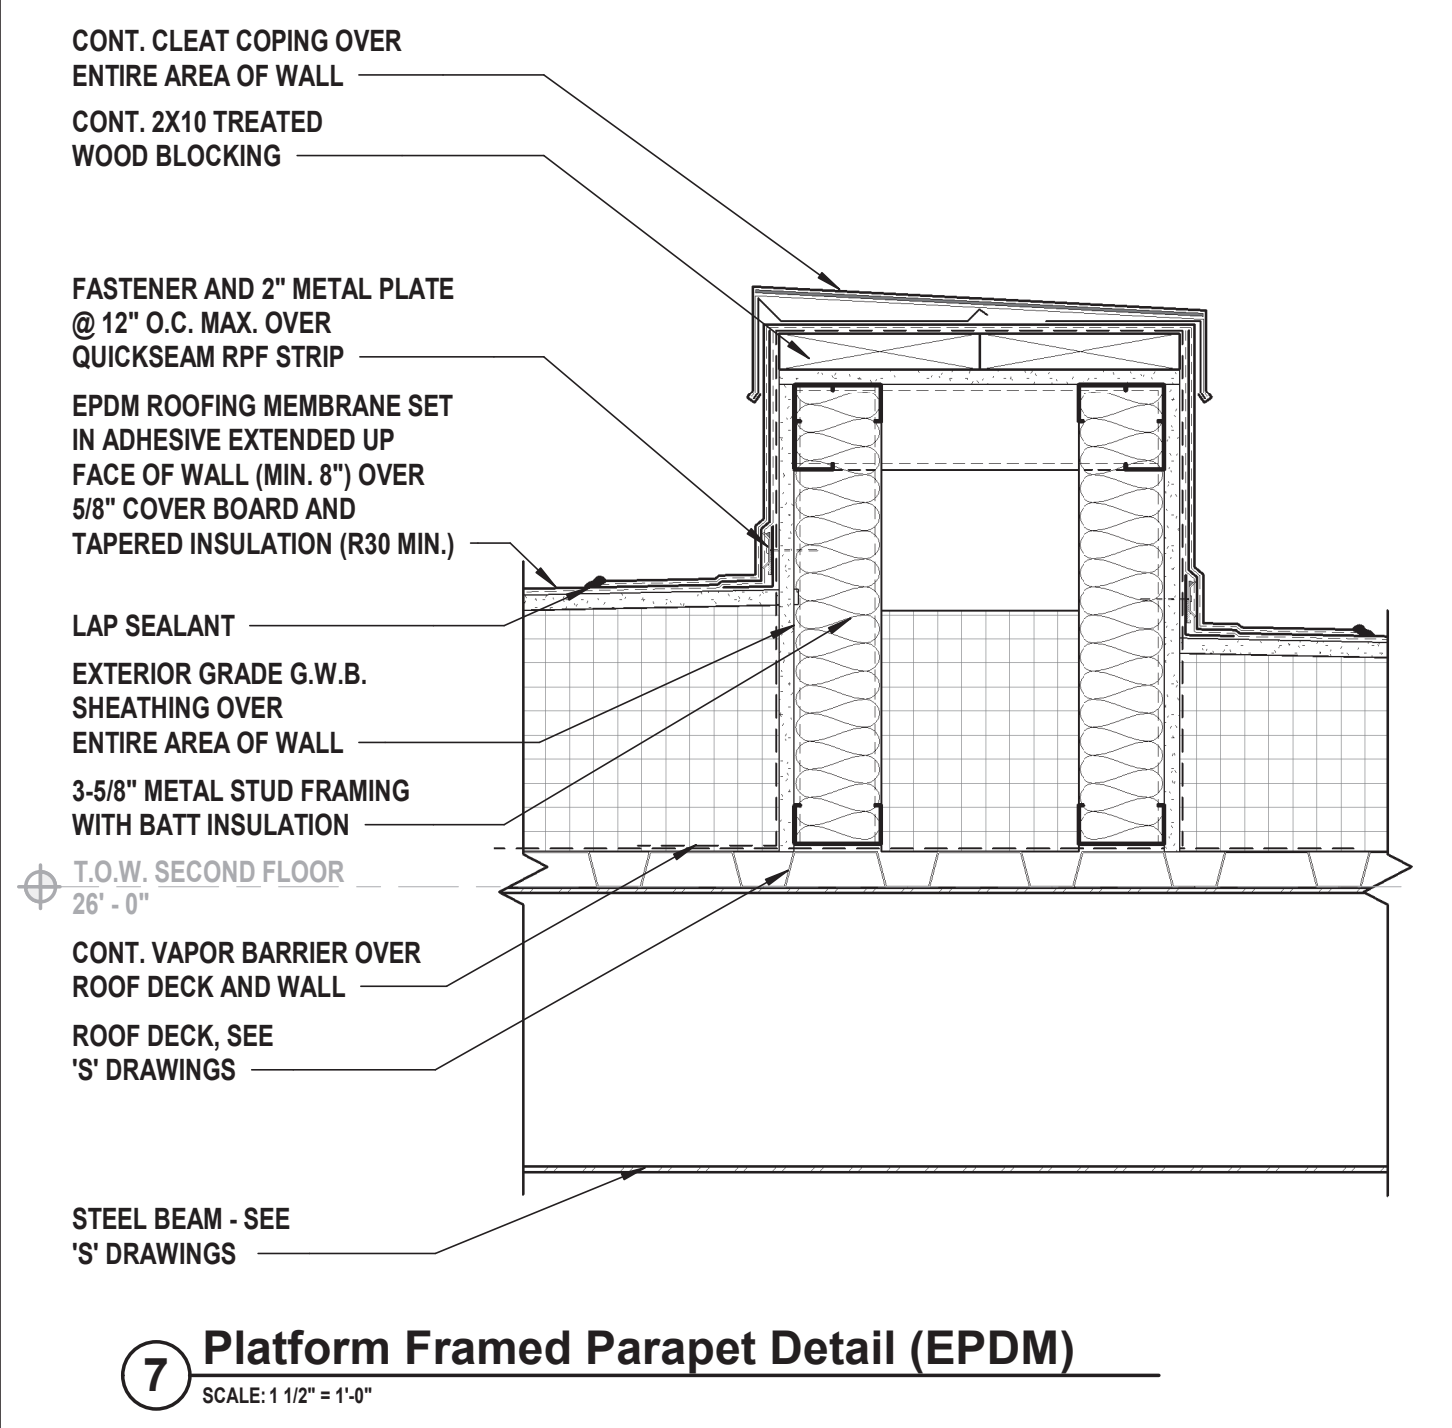

7 Platform Framed Parapet Detail (EPDM)
SCALE: 1 1/2" = 1'-0"

CONSULTANTS:		

MARK	DATE	DESCRIPTION



10/31/2025

Exp. Date

PATRICK O. STONE, R.A.

NY PROFESSIONAL ARCHITECT LIC. NO. 039654

IN ACCORDANCE WITH ARTICLE 146, SECTION 1209 OF THE NYS EDUCATION LAW, ALTERNATION OF THIS DOCUMENT EXCEPT BY A LICENSED PROFESSIONAL IS ILLEGAL.

DESIGNED BY:	DRAWN BY:	CHECKED BY:	REVIEWED BY:
DBS/RLG	ANK	DBS	POS
PROJECT No:	DATE:	SCALE:	AS SHOWN
TRFD 2302	FEBRUARY 2025		

CLIENT

**THIELLS
ROSEVILLE FIRE
DISTRICT**

**NEW 26-100 FIRE
HEADQUARTERS**



**65 W RAMAPO ROAD
GARNERVILLE, NY 10923**

CONTRACT

**CONTRACT G
GENERAL CONSTRUCTION**

STATUS

FINAL BID DOCUMENT

SHEET TITLE

ROOFING DETAILS

DRAWING No.

A 132.00

CONSULTANTS:		

MARK	DATE	DESCRIPTION

Patrick O. Stone

10/31/2025

Exp. Date

PATRICK O. STONE, R.A.

NY PROFESSIONAL ARCHITECT LIC. NO. 039654

*IN ACCORDANCE WITH ARTICLE 148, SECTION 1209 OF THE NYS EDUCATION LAW,
ALTACTION OF THIS DOCUMENT EXCEPT BY A LICENSED PROFESSIONAL IS ILLEGAL.

DESIGNED BY:	DRAWN BY:	CHECKED BY:	REVIEWED BY:
DBS/RLG	ANK/KAP	DBS	POS
PROJECT No:	DATE:	SCALE:	AS SHOWN
TRFD 2302	FEBRUARY 2025		

CLIENT

THIELLS
ROSEVILLE FIRE
DISTRICT

NEW 26-100 FIRE
HEADQUARTERS

65 W RAMAPO ROAD
GARNERVILLE, NY 10923

CONTRACT

CONTRACT G
GENERAL CONSTRUCTION

STATUS

FINAL BID DOCUMENT

SHEET TITLE



BUILDING ELEVATIONS


DRAWING No.

A 200.00


MATERIAL LEGEND	
	INDICATES AREA OF MASONRY CAVITY WALL CONSTRUCTION TO INCLUDE A BRICK VENEER OVER A CMU BACKUP. BRICK VENEER COLOR AND BOND TYPE TO BE SELECTED BY OWNER/ARCHITECT, SEE WALL TYPES FOR ADDITIONAL INFORMATION
	INDICATES AREA OF CEMENTITIOUS PANEL, COLOR AND STYLE TO BE DETERMINED IN FIELD BY OWNER/ARCHITECT, SEE WALL TYPES FOR ADDITIONAL INFORMATION
	INDICATES AREA OF ADHERED MANUFACTURED STONE VENEER. COLOR AND STYLE TO BE DETERMINED IN FIELD BY OWNER/ARCHITECT, SEE WALL TYPES FOR ADDITIONAL INFORMATION
	INDICATES AREA OF METAL WALL CLADDING. COLOR & STYLE TO BE DETERMINED BY OWNER/ARCHITECT, SEE WALL TYPES FOR ADDITIONAL INFORMATION

ELEVATION KEYNOTE LEGEND	
KEYNOTE	DESCRIPTION
ELEV-01	EXTERIOR BUILDING MOUNTED SIGNAGE, REFER TO SIGNAGE DETAILS.
ELEV-02	CURTAIN WALL GLAZING SYSTEM, REFER TO DETAILS.
ELEV-03	STOREFRONT GLAZING SYSTEM, REFER TO DETAILS.
ELEV-04	CURTAIN WALL MOUNTED BUILDING ADDRESS SIGNAGE, 8" LETTERS, FONT TO BE SELECTED BY OWNER.
ELEV-05	RECESSED WALL MOUNTED LIGHT FIXTURE, COORDINATE WITH CONTRACT 'E' FOR ADDITIONAL INFORMATION.
ELEV-06	6" DIAMETER PAINTED PIPE BOLLARDS, REFER TO CIVIL DRAWINGS FOR ADDITIONAL DETAILS.
ELEV-07	STAINLESS STEEL CHANNEL SUPPORT, BY CONTRACT 'E'.
ELEV-08	ALUMINUM AND GLASS ENTRY DOORS, SEE DOOR SCHEDULE FOR ADDITIONAL INFORMATION.
ELEV-09	FROST PROOF HOSE BIB, COORDINATE WITH CONTRACT 'P'.
ELEV-10	P.C. FOUNDATIONS AND FOOTINGS, REFER TO STRUCTURAL DRAWINGS FOR ADDITIONAL INFORMATION.
ELEV-11	LOUVER PROVIDED BY CONTRACT 'M', INSTALLED BY CONTRACT 'G'.
ELEV-12	PROVIDE AND INSTALL 4-EYEHOOKS SECURED INTO MASONRY BRICK VENEER AT OVERHEAD DOORS, TYP. OF 5 LOCATIONS. FINAL LOCATIONS TO BE COORDINATED IN FIELD WITH ARCHITECT/OWNER.
ELEV-13	SOLAR SUNSHADE, PROVIDED AND INSTALLED BY CONTRACT 'G'.
ELEV-14	ALUMINUM FASCIA, REFER TO ROOF DETAILS FOR ADDITIONAL INFORMATION.
ELEV-15	ROOF LADDER, SEE ROOF PLAN FOR ADDITIONAL INFORMATION.
ELEV-16	MECHANICAL EQUIPMENT - REFER TO MECHANICAL DRAWINGS FOR ADDITIONAL INFORMATION.
ELEV-17	ROOF HATCH, SEE ROOF PLAN FOR ADDITIONAL INFORMATION.
ELEV-18	EXTERIOR LIGHT FIXTURE, BY CONTRACT 'E'.
ELEV-19	GAS METER AND PIPING, BY CONTRACT 'P'.
ELEV-20	ELECTRICAL METER, BY CONTRACT 'E'.
ELEV-21	CURRENT TRANSFORMER (CT) CABINET BY CONTRACT 'E'.
ELEV-22	POLE MOUNTED SIREN, PROVIDED BY OWNER, INSTALLED BY CONTRACT 'G'.
ELEV-23	ROOF MOUNTED RADIO TOWER, PROVIDED BY OWNER, CONTRACT 'G' TO COORDINATE FINAL INSTALL.
ELEV-24	FIRE DEPARTMENT CONNECTION, REFER TO FIRE PROTECTION DRAWINGS.

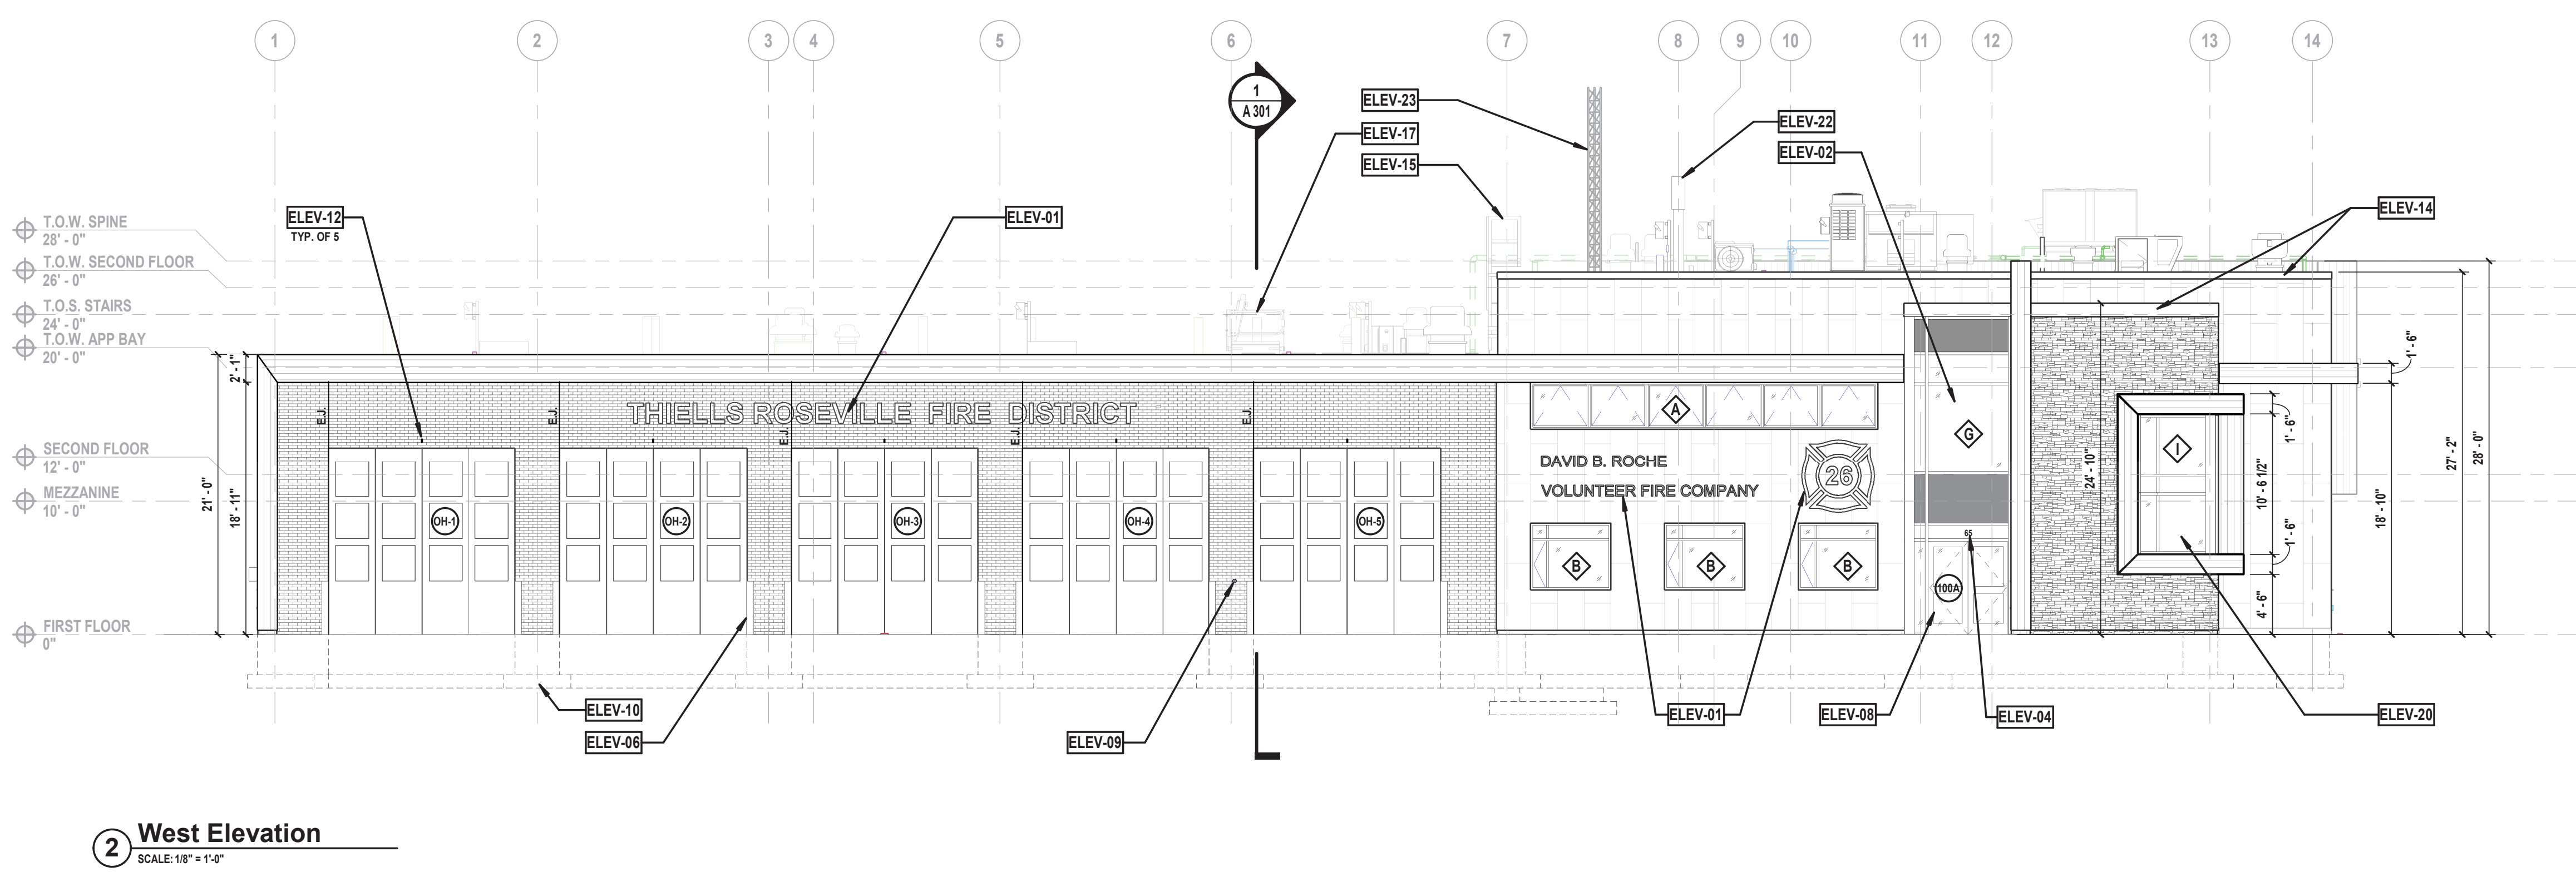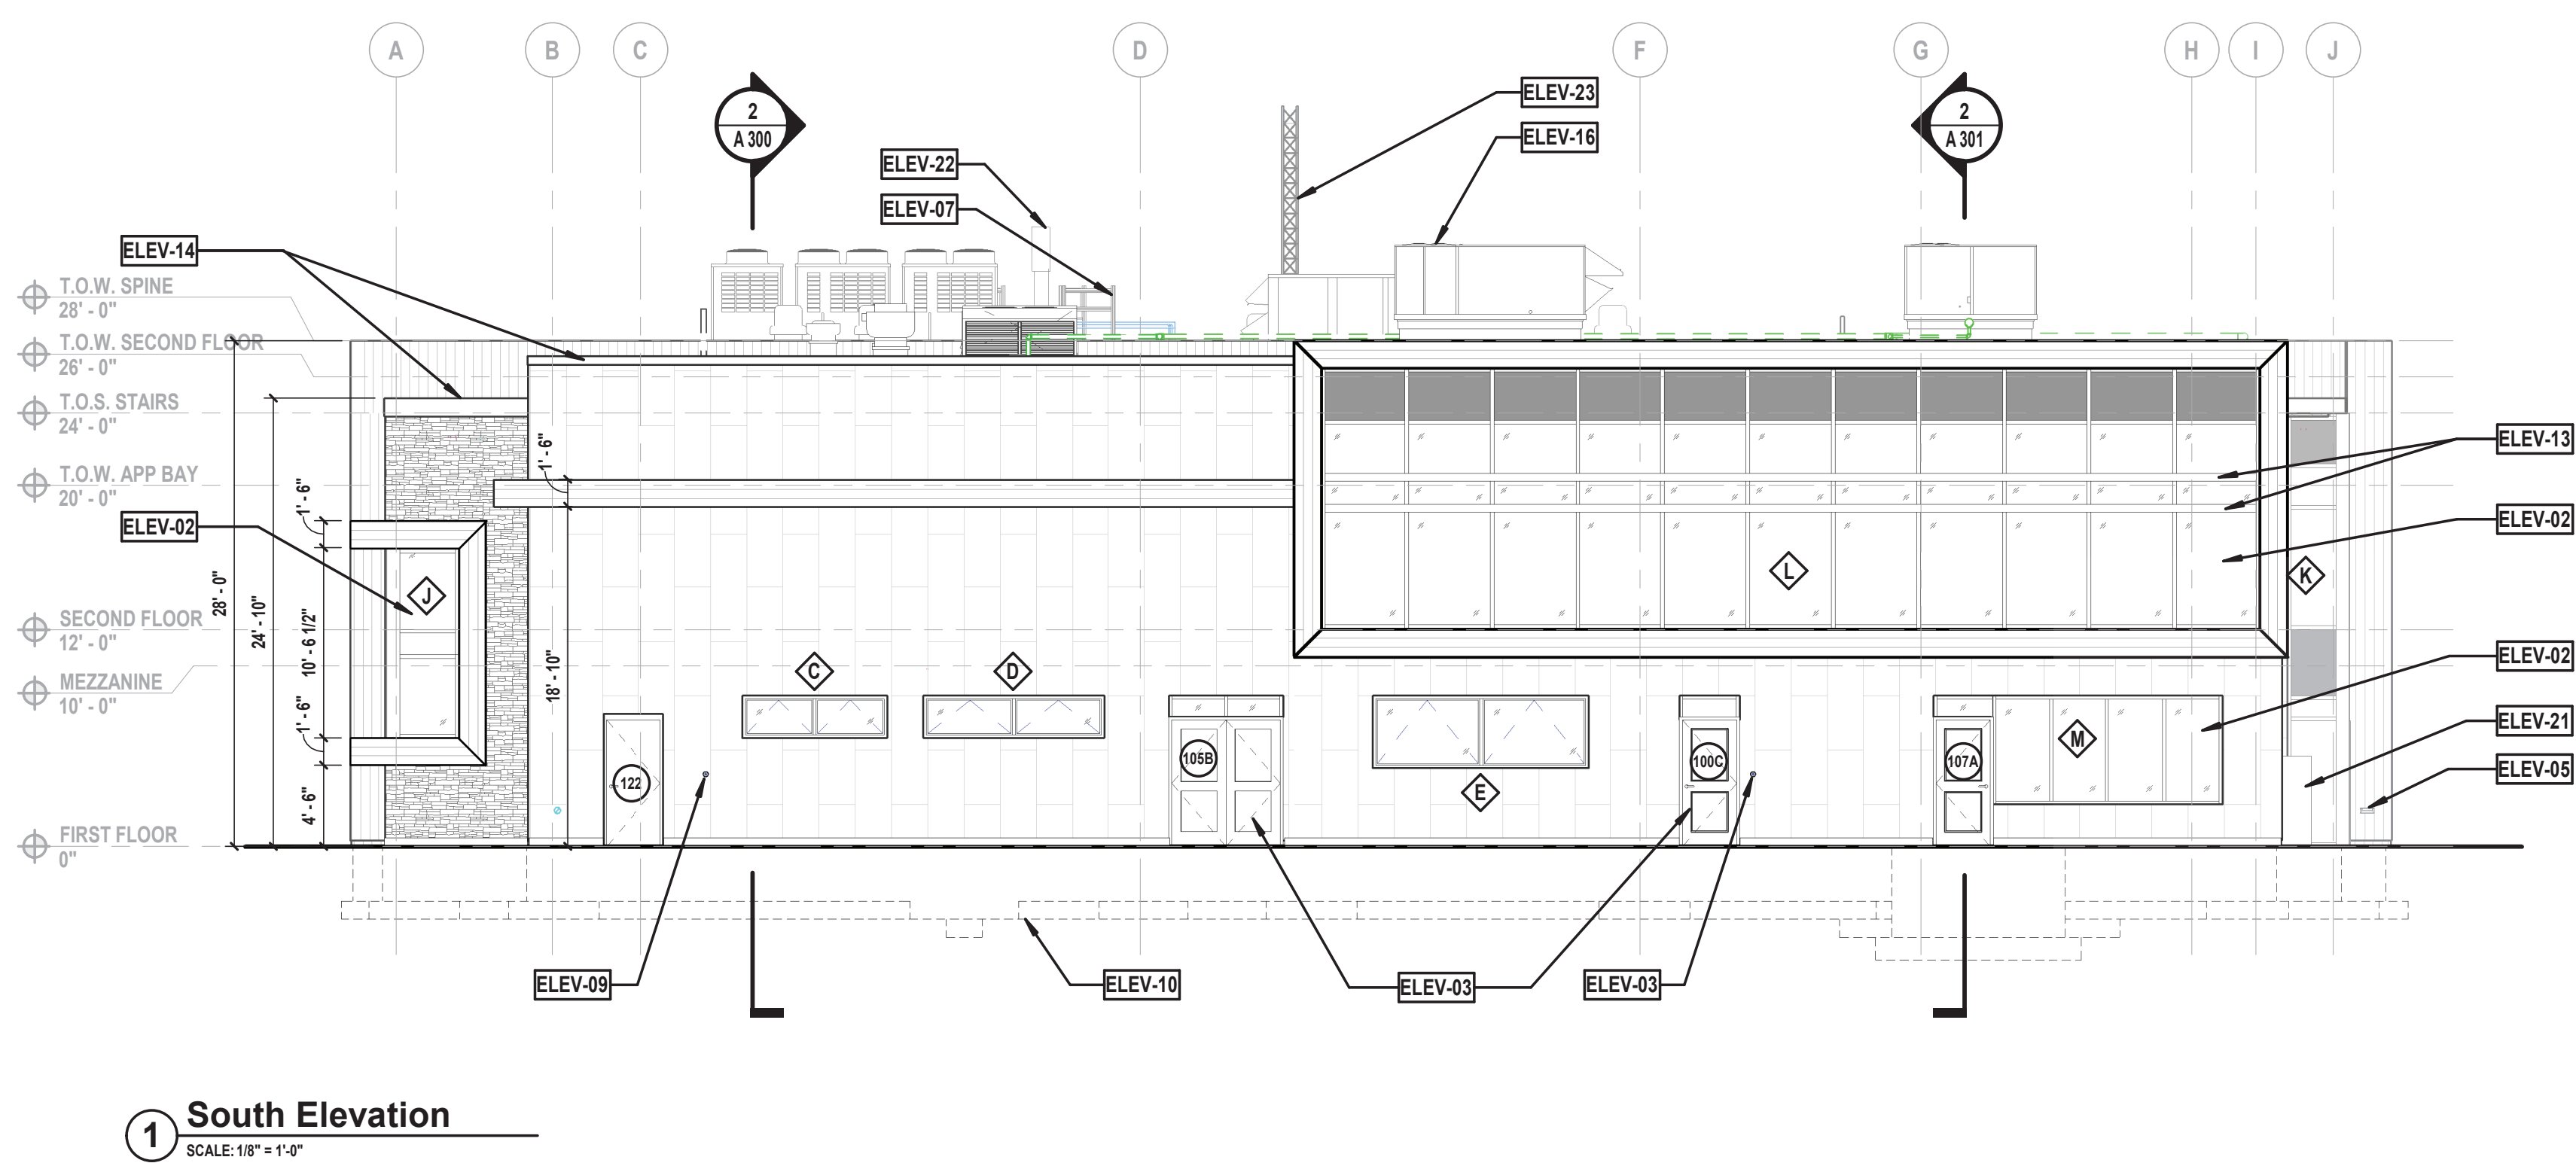

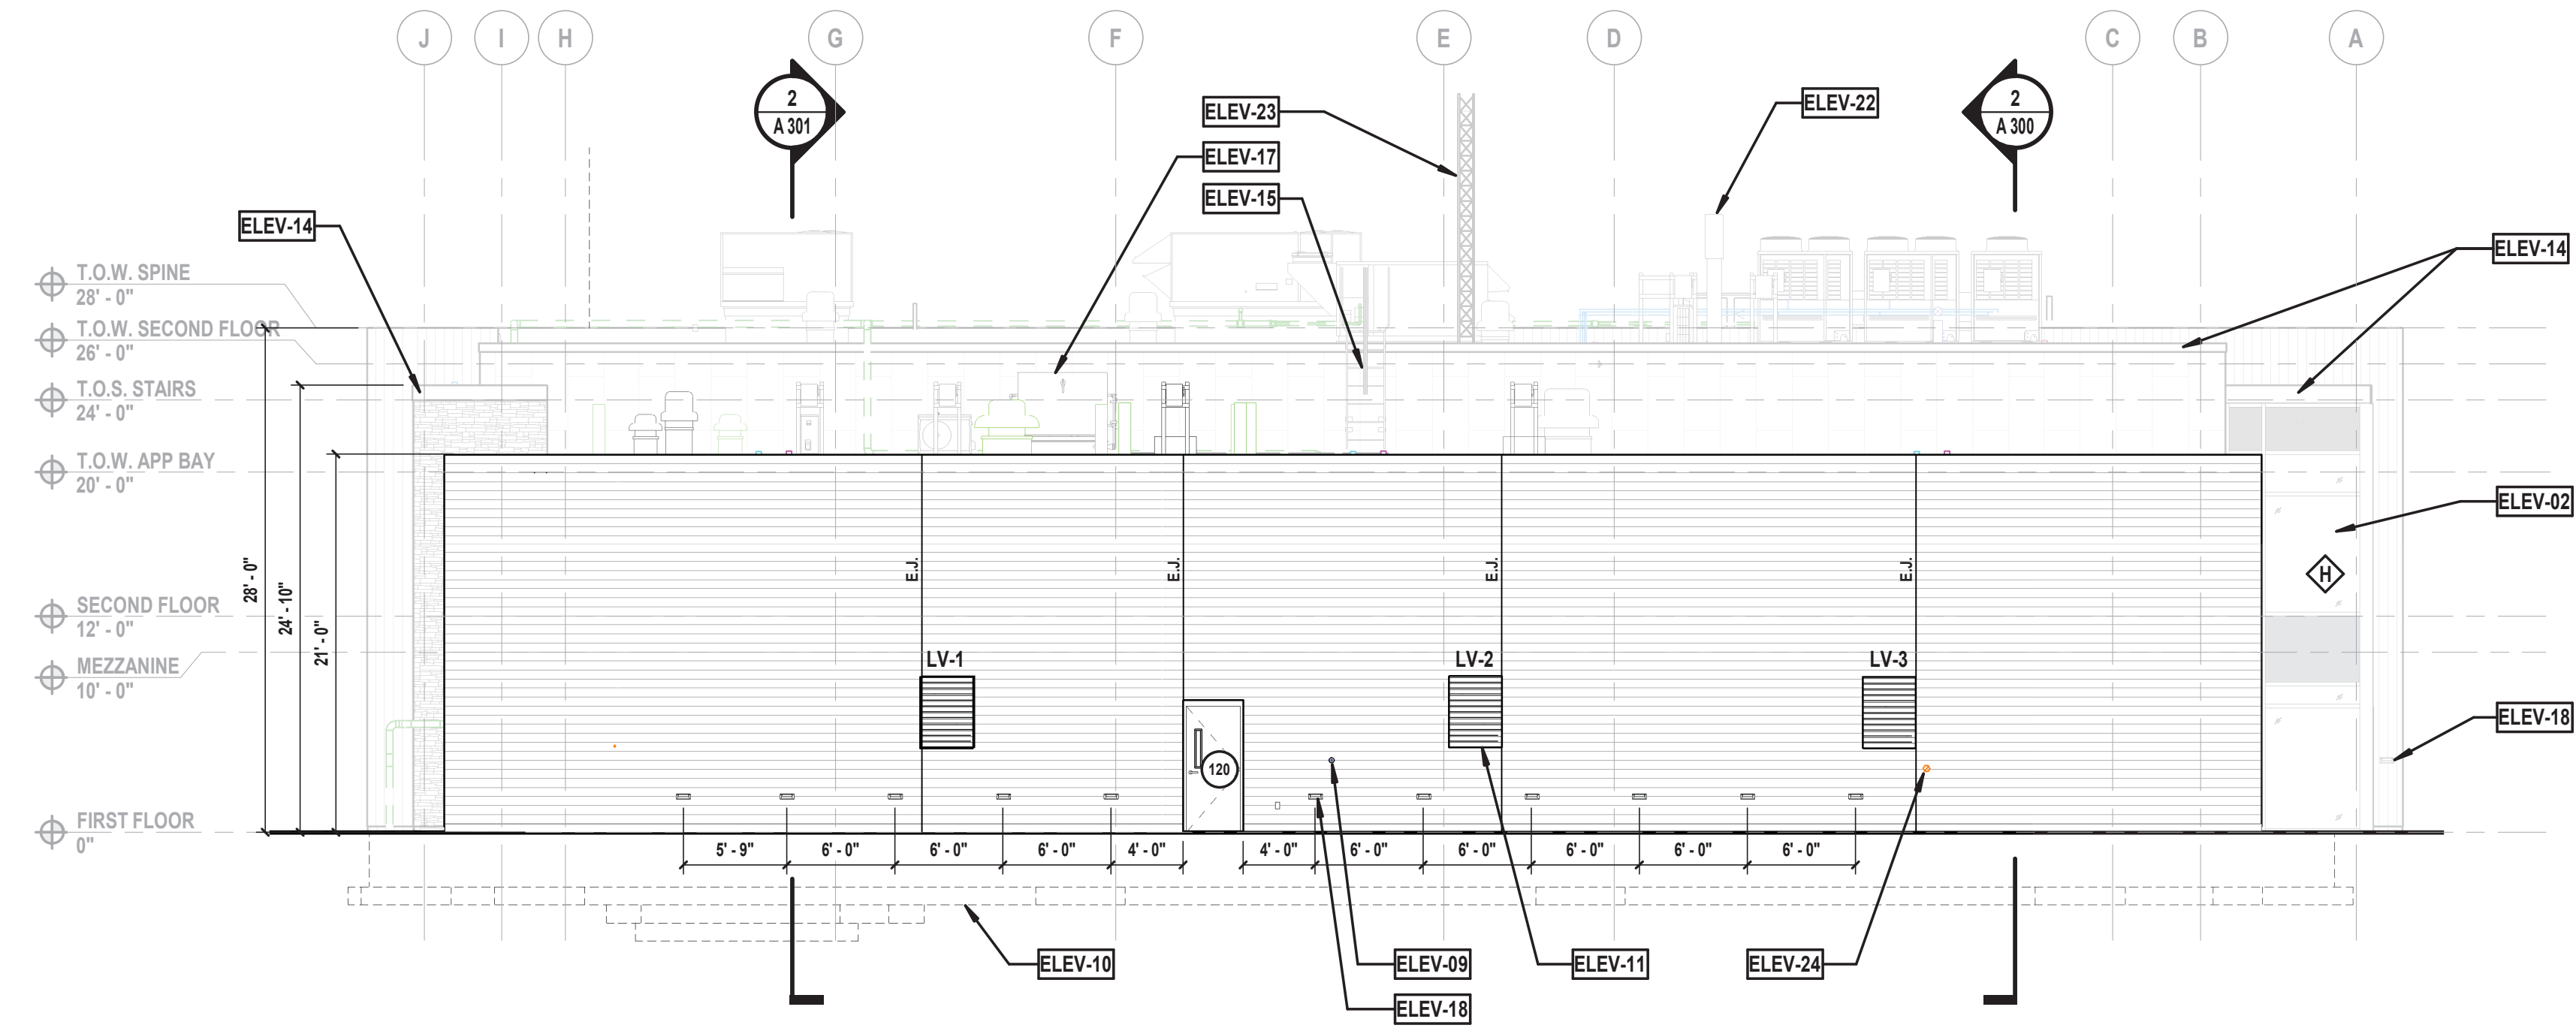

1 North Elevation
SCALE: 1/8" = 1'-0"

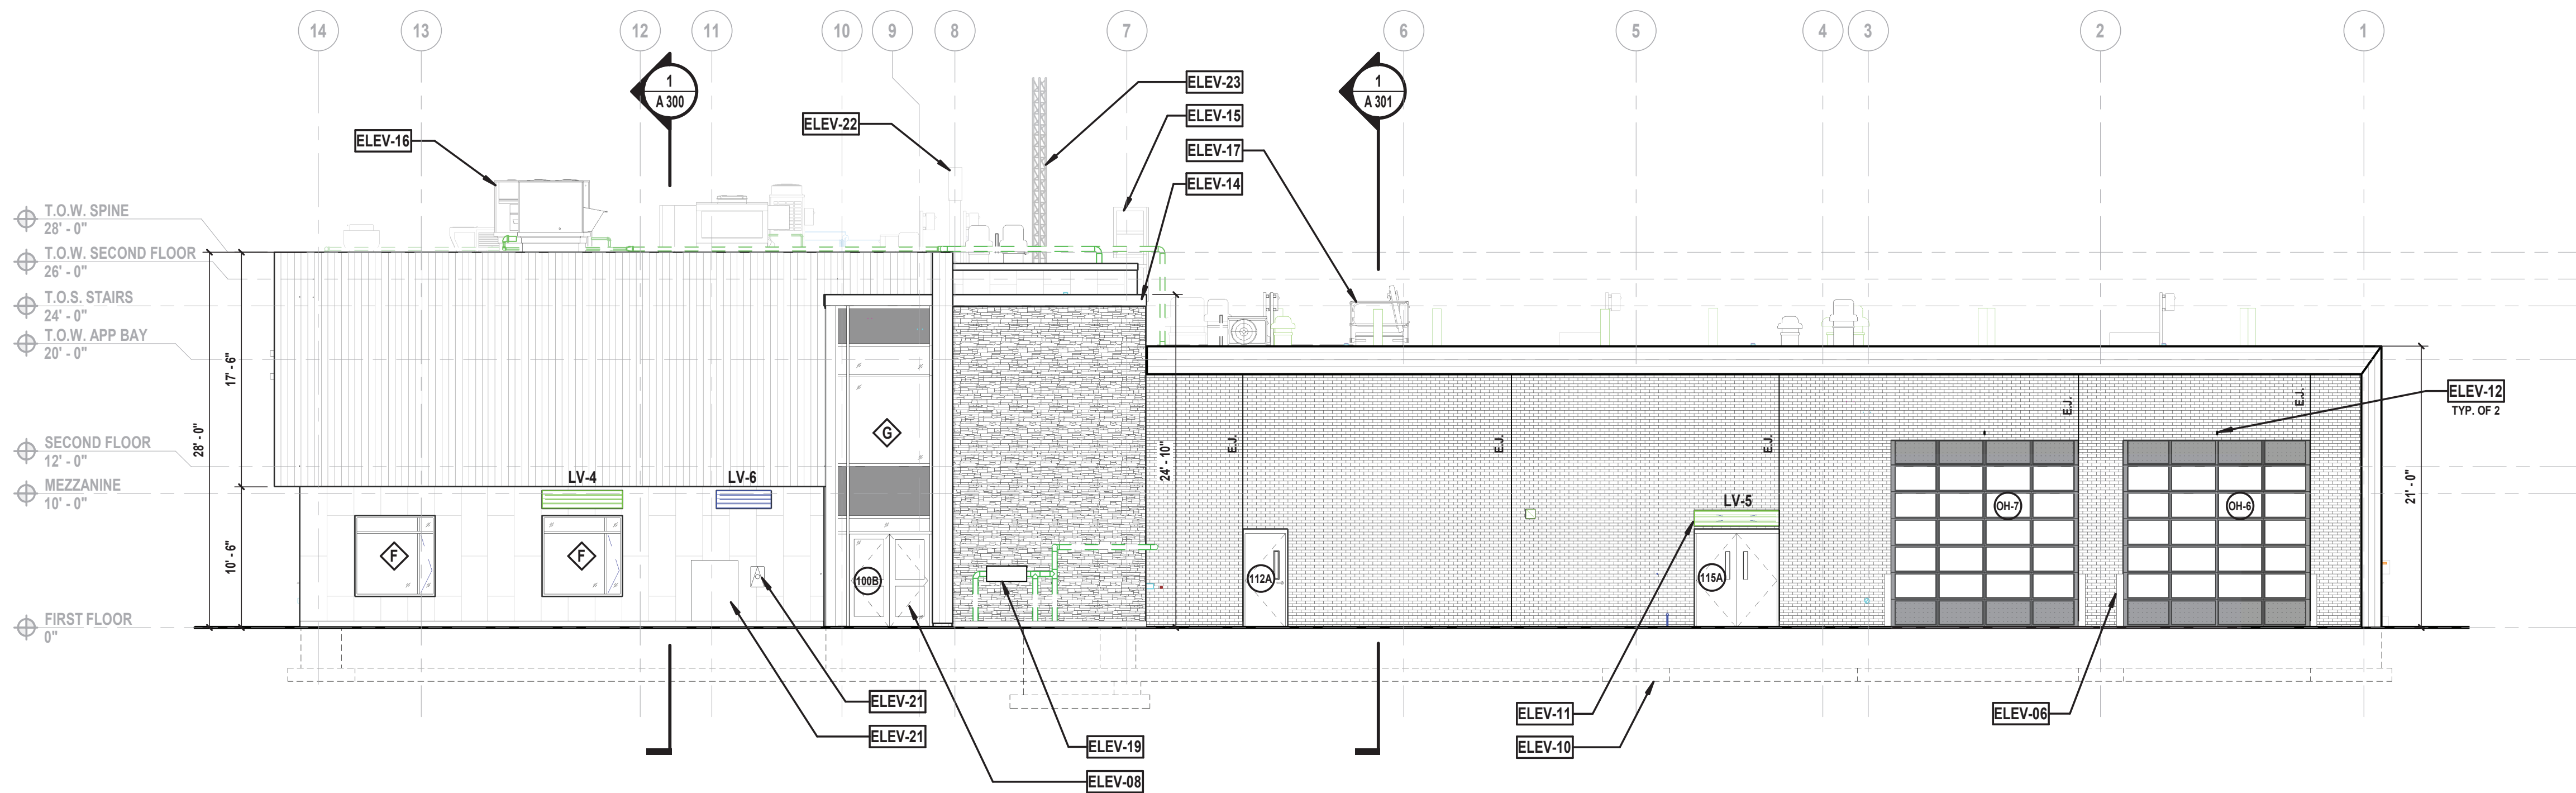


2 East Elevation
SCALE: 1/8" = 1'-0"

MATERIAL LEGEND

	INDICATES AREA OF MASONRY CAVITY WALL CONSTRUCTION TO INCLUDE A BRICK VENEER OVER A CMU BACKUP. BRICK VENEER COLOR AND BOND TYPE TO BE SELECTED BY OWNER/ARCHITECT, SEE WALL TYPES FOR ADDITIONAL INFORMATION
	INDICATES AREA OF CEMENTITIOUS PANEL, COLOR AND STYLE TO BE DETERMINED IN FIELD BY OWNER/ARCHITECT, SEE WALL TYPES FOR ADDITIONAL INFORMATION
	INDICATES AREA OF ADHERED MANUFACTURED STONE VENEER. COLOR AND STYLE TO BE DETERMINED IN FIELD BY OWNER/ARCHITECT, SEE WALL TYPES FOR ADDITIONAL INFORMATION
	INDICATES AREA OF METAL WALL CLADDING. COLOR & STYLE TO BE DETERMINED BY OWNER/ARCHITECT, SEE WALL TYPES FOR ADDITIONAL INFORMATION

ELEVATION KEYNOTE LEGEND


KEYNOTE	DESCRIPTION
ELEV-01	EXTERIOR BUILDING MOUNTED SIGNAGE, REFER TO SIGNAGE DETAILS.
ELEV-02	CURTAIN WALL GLAZING SYSTEM, REFER TO DETAILS.
ELEV-03	STOREFRONT GLAZING SYSTEM, REFER TO DETAILS.
ELEV-04	CURTAIN WALL MOUNTED BUILDING ADDRESS SIGNAGE, 8" LETTERS, FONT TO BE SELECTED BY OWNER.
ELEV-05	RECESSED WALL MOUNTED LIGHT FIXTURE, COORDINATE WITH CONTRACT 'E' FOR ADDITIONAL INFORMATION.
ELEV-06	6" DIAMETER PAINTED PIPE BOLLARDS, REFER TO CIVIL DRAWINGS FOR ADDITIONAL DETAILS.
ELEV-07	STAINLESS STEEL CHANNEL SUPPORT, BY CONTRACT 'E'.
ELEV-08	ALUMINUM AND GLASS ENTRY DOORS, SEE DOOR SCHEDULE FOR ADDITIONAL INFORMATION.
ELEV-09	FROST PROOF HOSE BIB, COORDINATE WITH CONTRACT 'P'.
ELEV-10	P.C. FOUNDATIONS AND FOOTINGS, REFER TO STRUCTURAL DRAWINGS FOR ADDITIONAL INFORMATION.
ELEV-11	LOUVER PROVIDED BY CONTRACT 'M', INSTALLED BY CONTRACT 'G'.
ELEV-12	PROVIDE AND INSTALL 4-EYEHOOKS SECURED INTO MASONRY BRICK VENEER AT OVERHEAD DOORS, TYP. OF 5 LOCATIONS. FINAL LOCATIONS TO BE COORDINATED IN FIELD WITH ARCHITECT/OWNER.
ELEV-13	SOLAR SUNSHADE, PROVIDED AND INSTALLED BY CONTRACT 'G'.
ELEV-14	ALUMINUM FASCIA, REFER TO ROOF DETAILS FOR ADDITIONAL INFORMATION.
ELEV-15	ROOF LADDER, SEE ROOF PLAN FOR ADDITIONAL INFORMATION.
ELEV-16	MECHANICAL EQUIPMENT - REFER TO MECHANICAL DRAWINGS FOR ADDITIONAL INFORMATION.
ELEV-17	ROOF HATCH, SEE ROOF PLAN FOR ADDITIONAL INFORMATION.
ELEV-18	EXTERIOR LIGHT FIXTURE, BY CONTRACT 'E'.
ELEV-19	GAS METER AND PIPING, BY CONTRACT 'P'.
ELEV-20	ELECTRICAL METER, BY CONTRACT 'E'.
ELEV-21	CURRENT TRANSFORMER (CT) CABINET BY CONTRACT 'E'.
ELEV-22	POLE MOUNTED SIREN, PROVIDED BY OWNER, INSTALLED BY CONTRACT 'G'.
ELEV-23	ROOF MOUNTED RADIO TOWER, PROVIDED BY OWNER, CONTRACT 'G' TO COORDINATE FINAL INSTALL.
ELEV-24	FIRE DEPARTMENT CONNECTION, REFER TO FIRE PROTECTION DRAWINGS.

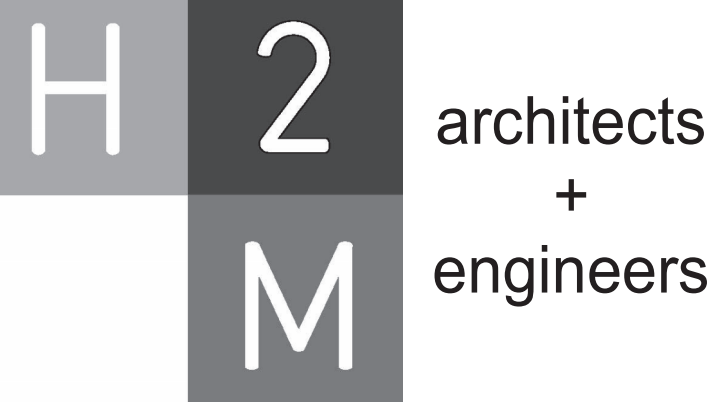

538 Broad Hollow Road, 4th Floor East
Melville, NY 11747
631.756.8000 • www.h2m.com
NY Architecture & Landscape Architecture: No Certificate Required
NY Engineering Certificate of Authorization No.: 0018178

CONSULTANTS:		

MARK	DATE	DESCRIPTION

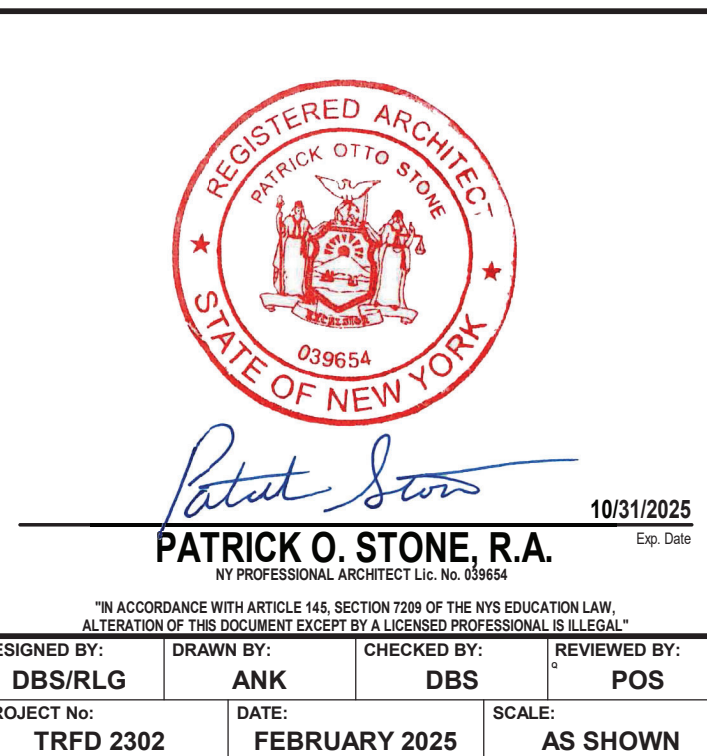

CLIENT

**THIELLS
ROSEVILLE FIRE
DISTRICT**

**NEW 26-100 FIRE
HEADQUARTERS**

**65 W RAMAPO ROAD
GARNERVILLE, NY 10923**

CONTRACT

**CONTRACT G
GENERAL CONSTRUCTION**

STATUS

FINAL BID DOCUMENT

SHEET TITLE

BUILDING ELEVATIONS

DRAWING No.

A 201.00

CONSULTANTS:		

MARK	DATE	DESCRIPTION

REGISTERED ARCHITECT
PATRICK O. STONE
STATE OF NEW YORK
029654


PATRICK O. STONE, R.A.
NY PROFESSIONAL ARCHITECT LIC. NO. 039654

10/31/2025
Exp. Date

*IN ACCORDANCE WITH ARTICLE 145, SECTION 1209 OF THE NYS EDUCATION LAW,
ALTACTION OF THIS DOCUMENT EXCEPT BY A LICENSED PROFESSIONAL IS ILLEGAL.

DESIGNED BY:	DRAWN BY:	CHECKED BY:	REVIEWED BY:
DBS/RLG	ANK	DBS	POS
PROJECT No:	DATE:	SCALE:	AS SHOWN
TRFD 2302	FEBRUARY 2025		

CLIENT

THIELLS
ROSEVILLE FIRE
DISTRICT

NEW 26-100 FIRE
HEADQUARTERS



65 W RAMAPO ROAD
GARNERVILLE, NY 10923

CONTRACT

CONTRACT G
GENERAL CONSTRUCTION

STATUS

FINAL BID DOCUMENT


SHEET TITLE

BUILDING SECTIONS


DRAWING No.

A 300.00

BUILDING SECTION KEYNOTE LEGEND	
KEYNOTE	DESCRIPTION
SEC-01	MASONRY CAVITY WALL WITH BRICK VENEER - STYLE/COLOR TO BE SELECTED IN FIELD BY ARCHITECT.
SEC-02	FOUR-FOLD DOOR, REFER TO DOOR SCHEDULE AND DETAILS FOR ADDITIONAL INFORMATION.
SEC-04	SUSPENDED CEILING, REFER TO RCP FOR ADDITIONAL INFORMATION.
SEC-05	WASHFOUNTAIN PROVIDED AND INSTALLED BY CONTRACT 'P', REFER TO 'P' DRAWINGS.
SEC-06	EPDM ROOFING MEMBRANE SET IN ADHESIVE EXTENDED UP FACE OF WALL (MIN. 12") OVER 5/8" COVER BOARD AND TAPERED INSULATION (R30 MIN.), REFER TO ROOF PLAN FOR ADDITIONAL INFORMATION.
SEC-07	ELEVATOR PIT, REFER TO MANUFACTURER'S SPECIFICATIONS.
SEC-08	EXPOSED STRUCTURAL STEEL, PAINT - TYP.
SEC-09	CONCRETE SLAB ON GRADE, SEE 'S' DRAWINGS FOR ADDITIONAL INFORMATION.
SEC-10	GAS DETECTION SYSTEM BY CONTRACT 'M', REFER TO 'M' DRAWINGS FOR ADDITIONAL INFORMATION.
SEC-11	BAILOUT TRAINING WINDOW, BULLNOSE ALL CORNERS AT PERIMETER OF WINDOW.
SEC-12	OPENING GUARD BEYOND.
SEC-13	HVLS FAN PROVIDED AND INSTALLED BY CONTRACT 'M', SEE 'M' DRAWINGS FOR ADDITIONAL INFORMATION.
SEC-14	GAS HEATER PROVIDED AND INSTALLED BY CONTRACT 'M', SEE 'M' DRAWINGS FOR ADDITIONAL INFORMATION.
SEC-15	ALUMINUM SHIPS STAIR LADDER TO ROOF HATCH, REFER TO SPECIFICATION FOR ADDITIONAL INFORMATION.
SEC-16	3/4" PLYWOOD FASTENED TO CMU - PAINT TO MATCH WALL.
SEC-17	PROVIDE ACCENT COLOR @ BAILOUT LOCATION.
SEC-18	TIE-OFF POINT, REFER TO DETAILS AND 'S' DRAWINGS.
SEC-19	PASS-THRU WINDOW.
SEC-20	EXTERIOR ALUMINUM SUNSHADE.
SEC-21	SAFETY GATE, REFER TO DOOR DETAILS FOR ADDITIONAL INFORMATION.
SEC-22	EMERGENCY EYE WASH STATION PROVIDED AND INSTALLED BY CONTRACT 'G'.
SEC-23	POLE MOUNTED SIREN, PROVIDED BY OWNER, INSTALLED BY CONTRACT 'G'.
SEC-24	ROOF MOUNTED RADIO TOWER, PROVIDED BY OWNER, CONTRACT 'G' TO COORDINATE FINAL INSTALL.

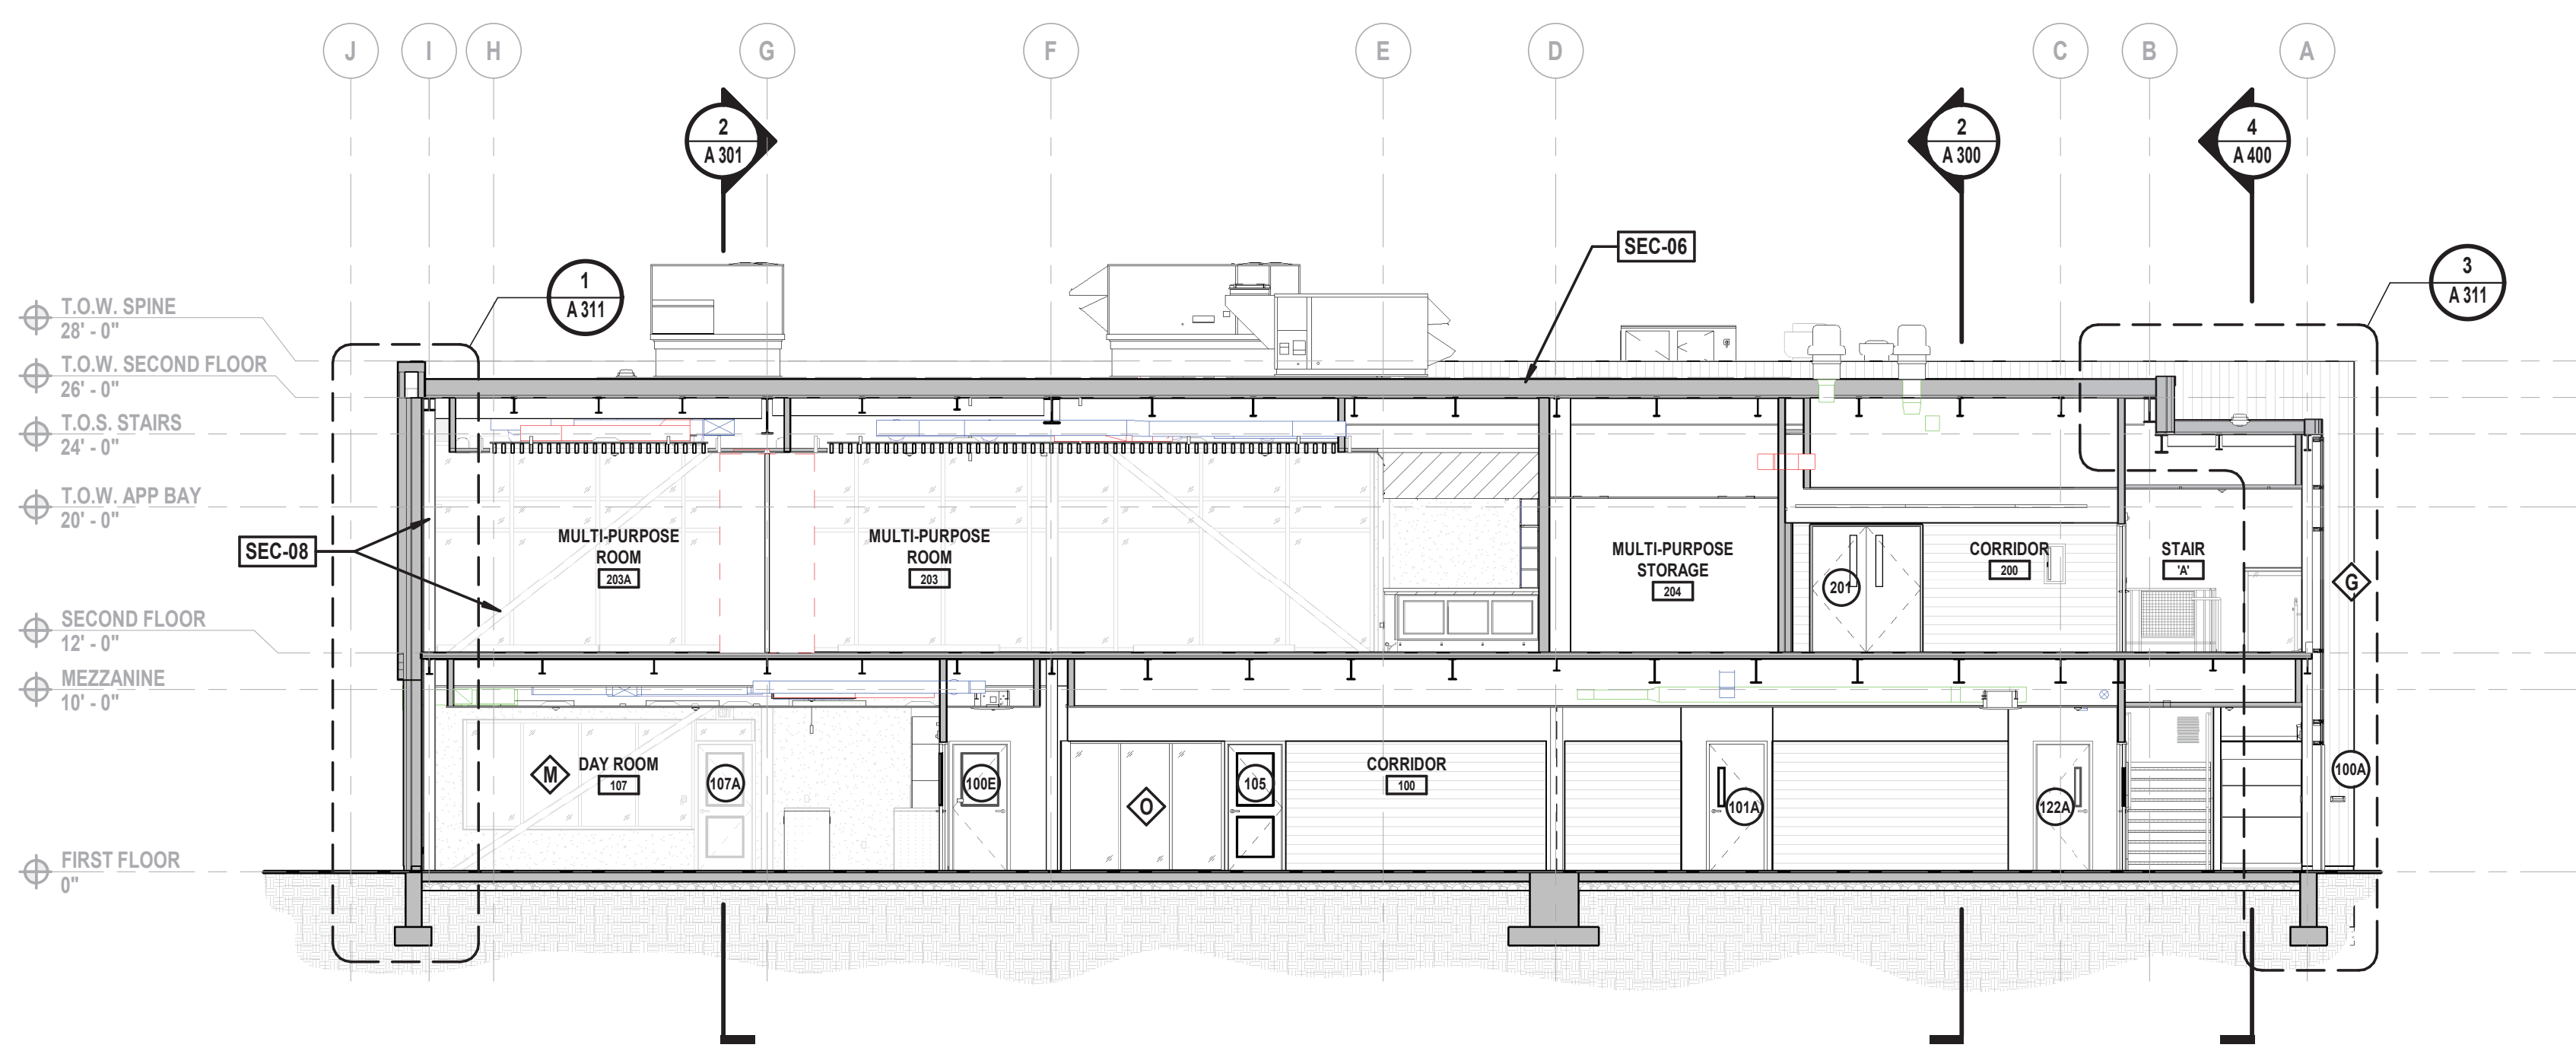

1 Building Section
SCALE: 1/8" = 1'-0"

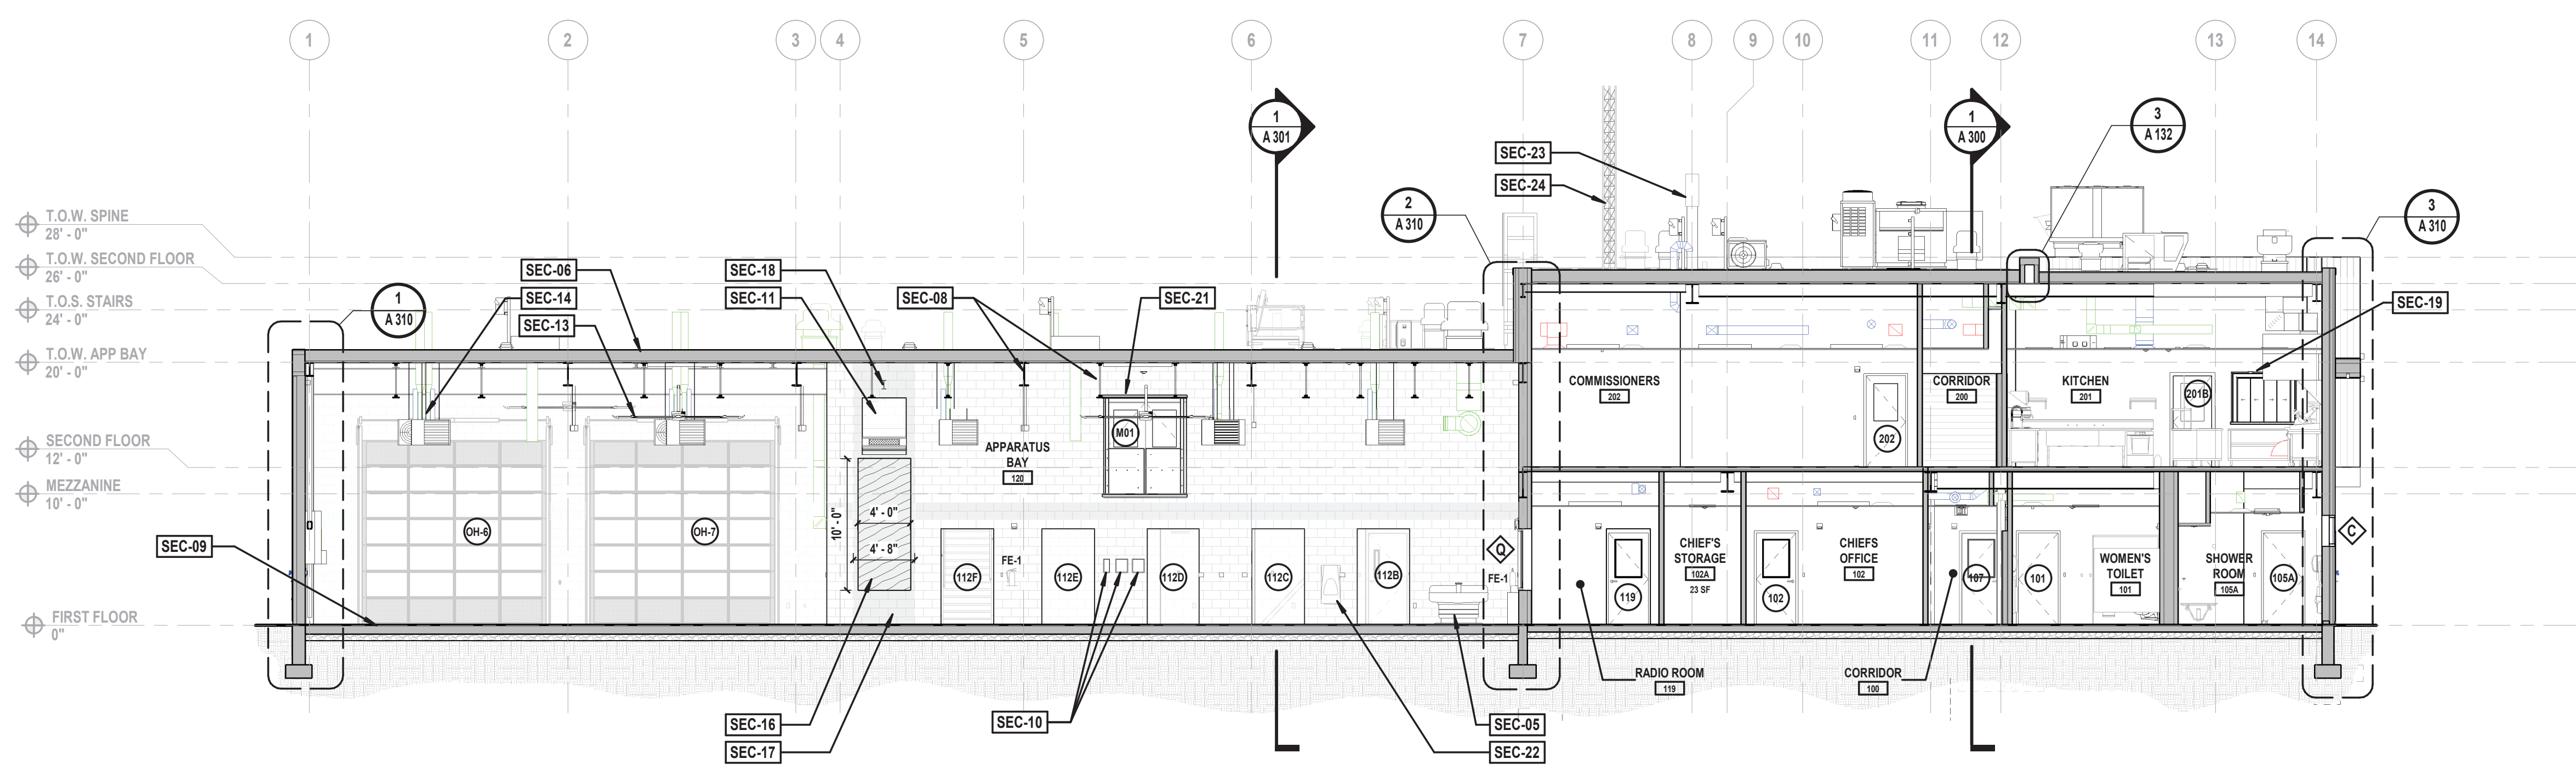

2 Building Section
SCALE: 1/8" = 1'-0"

CONSULTANTS:		

MARK	DATE	DESCRIPTION



10/31/2025

Exp. Date

PATRICK O. STONE, R.A.

NY PROFESSIONAL ARCHITECT LIC. NO. 039654

DBS/RLG

ANK

DBS

POS

DESIGNED BY:

DRAWN BY:

CHECKED BY:

REVIEWED BY:

PROJECT No:

DATE:

SCALE:

AS SHOWN

TRFD 2302

FEBRUARY 2025

CLIENT

THIELLS
ROSEVILLE FIRE
DISTRICT

NEW 26-100 FIRE
HEADQUARTERS



65 W RAMAPO ROAD
GARNERVILLE, NY 10923

CONTRACT

CONTRACT G
GENERAL CONSTRUCTION

STATUS

FINAL BID DOCUMENT

SHEET TITLE

BUILDING SECTIONS

DRAWING No.

A 301.00

BUILDING SECTION KEYNOTE LEGEND	
KEYNOTE	DESCRIPTION
SEC-01	MASONRY CAVITY WALL WITH BRICK VENEER - STYLE/COLOR TO BE SELECTED IN FIELD BY ARCHITECT.
SEC-02	FOUR-FOLD DOOR, REFER TO DOOR SCHEDULE AND DETAILS FOR ADDITIONAL INFORMATION.
SEC-04	SUSPENDED CEILING, REFER TO RCP FOR ADDITIONAL INFORMATION.
SEC-05	WASHFOUNTAIN PROVIDED AND INSTALLED BY CONTRACT 'P', REFER TO 'P' DRAWINGS.
SEC-06	EPDM ROOFING MEMBRANE SET IN ADHESIVE EXTENDED UP FACE OF WALL (MIN. 12") OVER 5/8" COVER BOARD AND TAPERED INSULATION (R30 MIN.), REFER TO ROOF PLAN FOR ADDITIONAL INFORMATION.
SEC-07	ELEVATOR PIT, REFER TO MANUFACTURER'S SPECIFICATIONS.
SEC-08	EXPOSED STRUCTURAL STEEL, PAINT - TYP.
SEC-09	CONCRETE SLAB ON GRADE, SEE 'S' DRAWINGS FOR ADDITIONAL INFORMATION.
SEC-10	GAS DETECTION SYSTEM BY CONTRACT 'M', REFER TO 'M' DRAWINGS FOR ADDITIONAL INFORMATION.
SEC-11	BAILOUT TRAINING WINDOW, BULLNOSE ALL CORNERS AT PERIMETER OF WINDOW.
SEC-12	OPENING GUARD BEYOND.
SEC-13	HVLS FAN PROVIDED AND INSTALLED BY CONTRACT 'M', SEE 'M' DRAWINGS FOR ADDITIONAL INFORMATION.
SEC-14	GAS HEATER PROVIDED AND INSTALLED BY CONTRACT 'M', SEE 'M' DRAWINGS FOR ADDITIONAL INFORMATION.
SEC-15	ALUMINUM SHIPS STAIR LADDER TO ROOF HATCH, REFER TO SPECIFICATION FOR ADDITIONAL INFORMATION.
SEC-16	3/4" PLYWOOD FASTENED TO CMU - PAINT TO MATCH WALL.
SEC-17	PROVIDE ACCENT COLOR @ BAILOUT LOCATION.
SEC-18	TIE-OFF POINT, REFER TO DETAILS AND 'S' DRAWINGS.
SEC-19	PASS-THRU WINDOW.
SEC-20	EXTERIOR ALUMINUM SUNSHADE.
SEC-21	SAFETY GATE, REFER TO DOOR DETAILS FOR ADDITIONAL INFORMATION.
SEC-22	EMERGENCY EYE WASH STATION PROVIDED AND INSTALLED BY CONTRACT 'G'.
SEC-23	POLE MOUNTED SIREN, PROVIDED BY OWNER, INSTALLED BY CONTRACT 'G'.
SEC-24	ROOF MOUNTED RADIO TOWER, PROVIDED BY OWNER, CONTRACT 'G' TO COORDINATE FINAL INSTALL.

1 Building Section
SCALE: 1/8" = 1'-0"

2 Building Section
SCALE: 1/8" = 1'-0"

C:\Users\skel\Documents\TRFD2302_Central23_A_A\skel.rvt 2/25/2025 4:07:52 PM

MARK	DATE	DESCRIPTION

REGISTERED ARCHITECT
PATRICK O. STONE, R.A.
NY PROFESSIONAL ARCHITECT LIC. NO. 039654
10/31/2025
Exp. Date
*IN ACCORDANCE WITH ARTICLE 145, SECTION 1209 OF THE NYS EDUCATION LAW,
ALTERNATION OF THIS DOCUMENT EXCEPT BY A LICENSED PROFESSIONAL IS ILLEGAL.*
DESIGNED BY: DBS/RLG DRAWN BY: KAP/ANK CHECKED BY: DBS REVIEWED BY: POS
PROJECT No: TRFD 2302 DATE: FEBRUARY 2025 SCALE: AS SHOWN

CLIENT
**THIELLS
ROSEVILLE FIRE
DISTRICT**

**NEW 26-100 FIRE
HEADQUARTERS**




65 W RAMAPO ROAD
GARNERVILLE, NY 10923


CONTRACT
**CONTRACT G
GENERAL CONSTRUCTION**

STATUS
FINAL BID DOCUMENT

SHEET TITLE
WALL SECTION

DRAWING No.
A 310.00

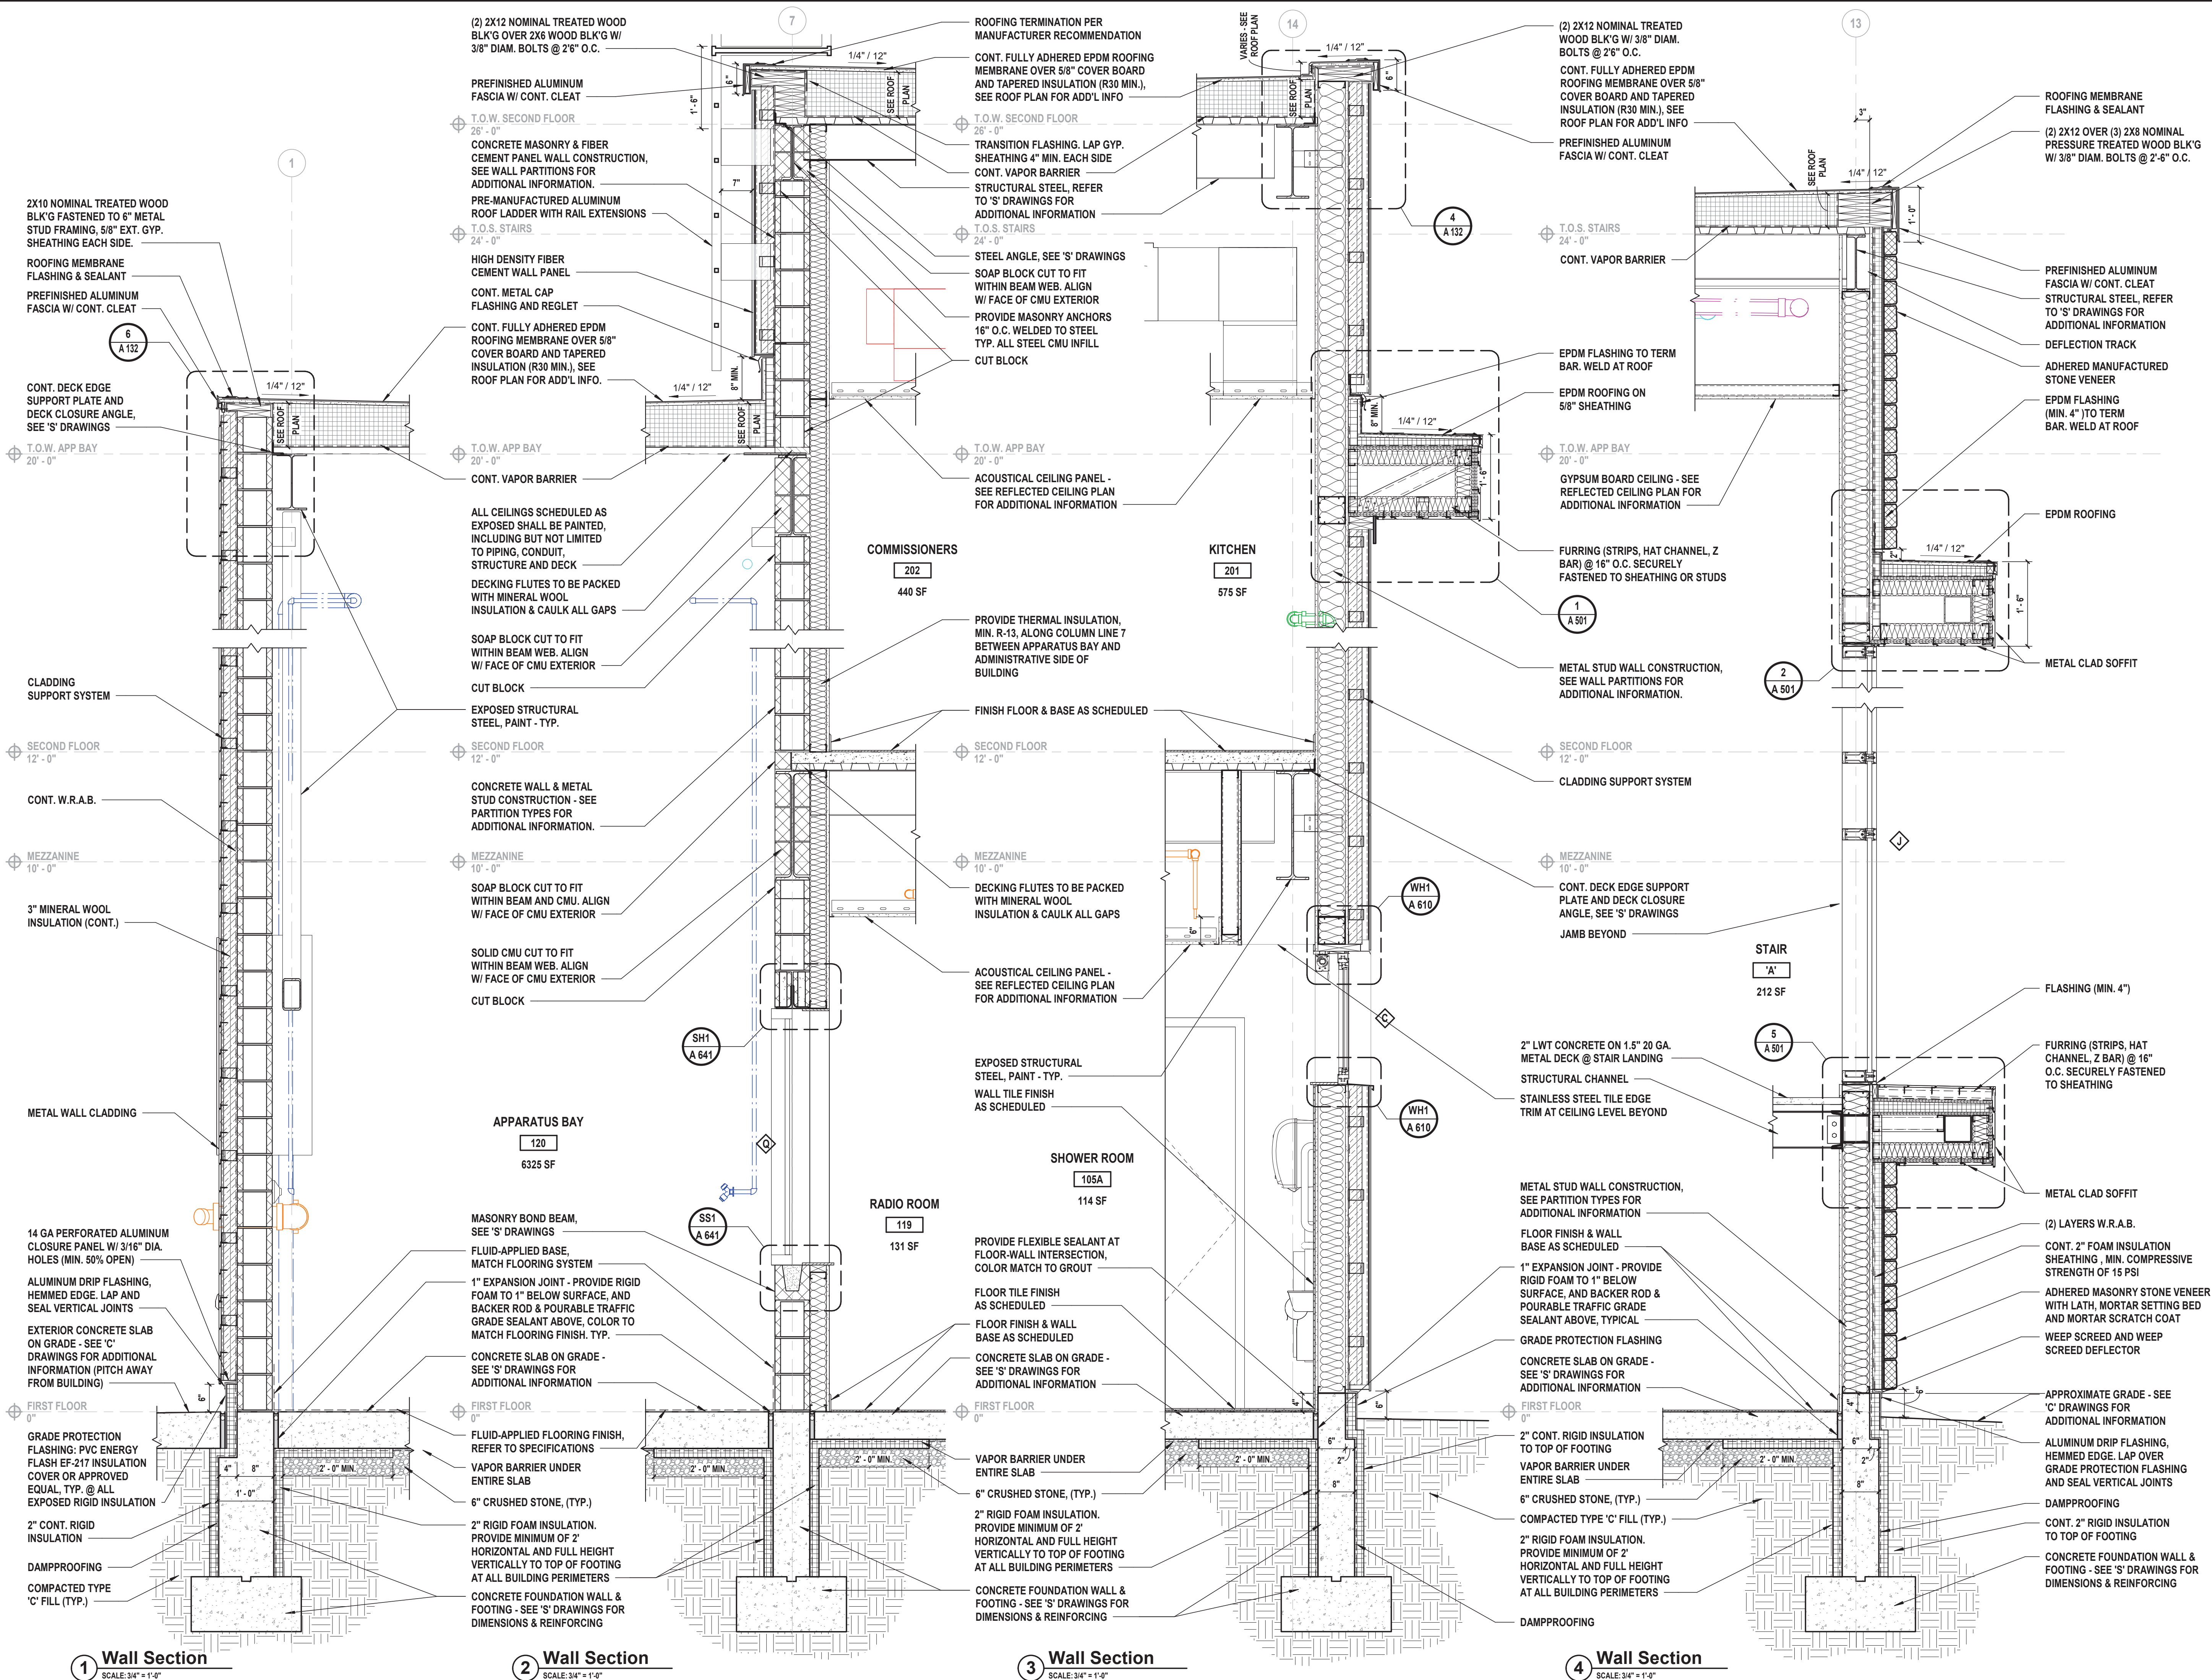

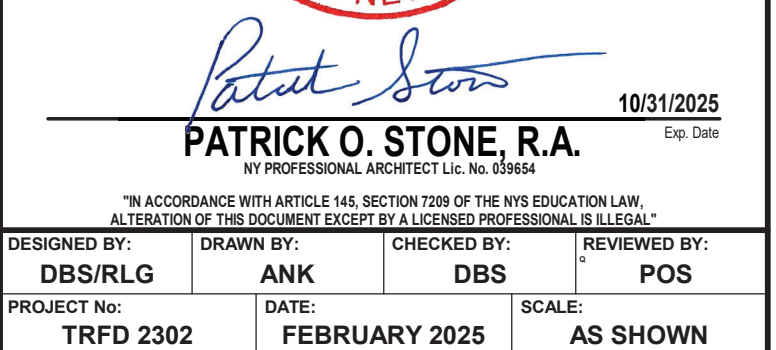[illegible]

**THIELLS
ROSEVILLE FIRE
DISTRICT**

CONTRACT



**CONTRACT G
GENERAL CONSTRUCTION**

STATUS	FINAL BID DOCUMENT
--------	--------------------

SHEET TITLE

WALL SECTION

  DRAWING No. **A 311.00**






ALTERNATION OF THIS DOCUMENT EXCEPT BY A LICENSED PROFESSIONAL IS ILLEGAL			
DESIGNED BY: DBS/RLG	DRAWN BY: ANK	CHECKED BY: DBS	REVIEWED BY: POS
PROJECT No: TRFD 2302	DATE: FEBRUARY 2025	SCALE: AS SHOWN	

NEW 26-100 FIRE HEADQUARTERS



STATUS **FINAL BID DOCUMENT**

DRAWING No. **A 312.00**

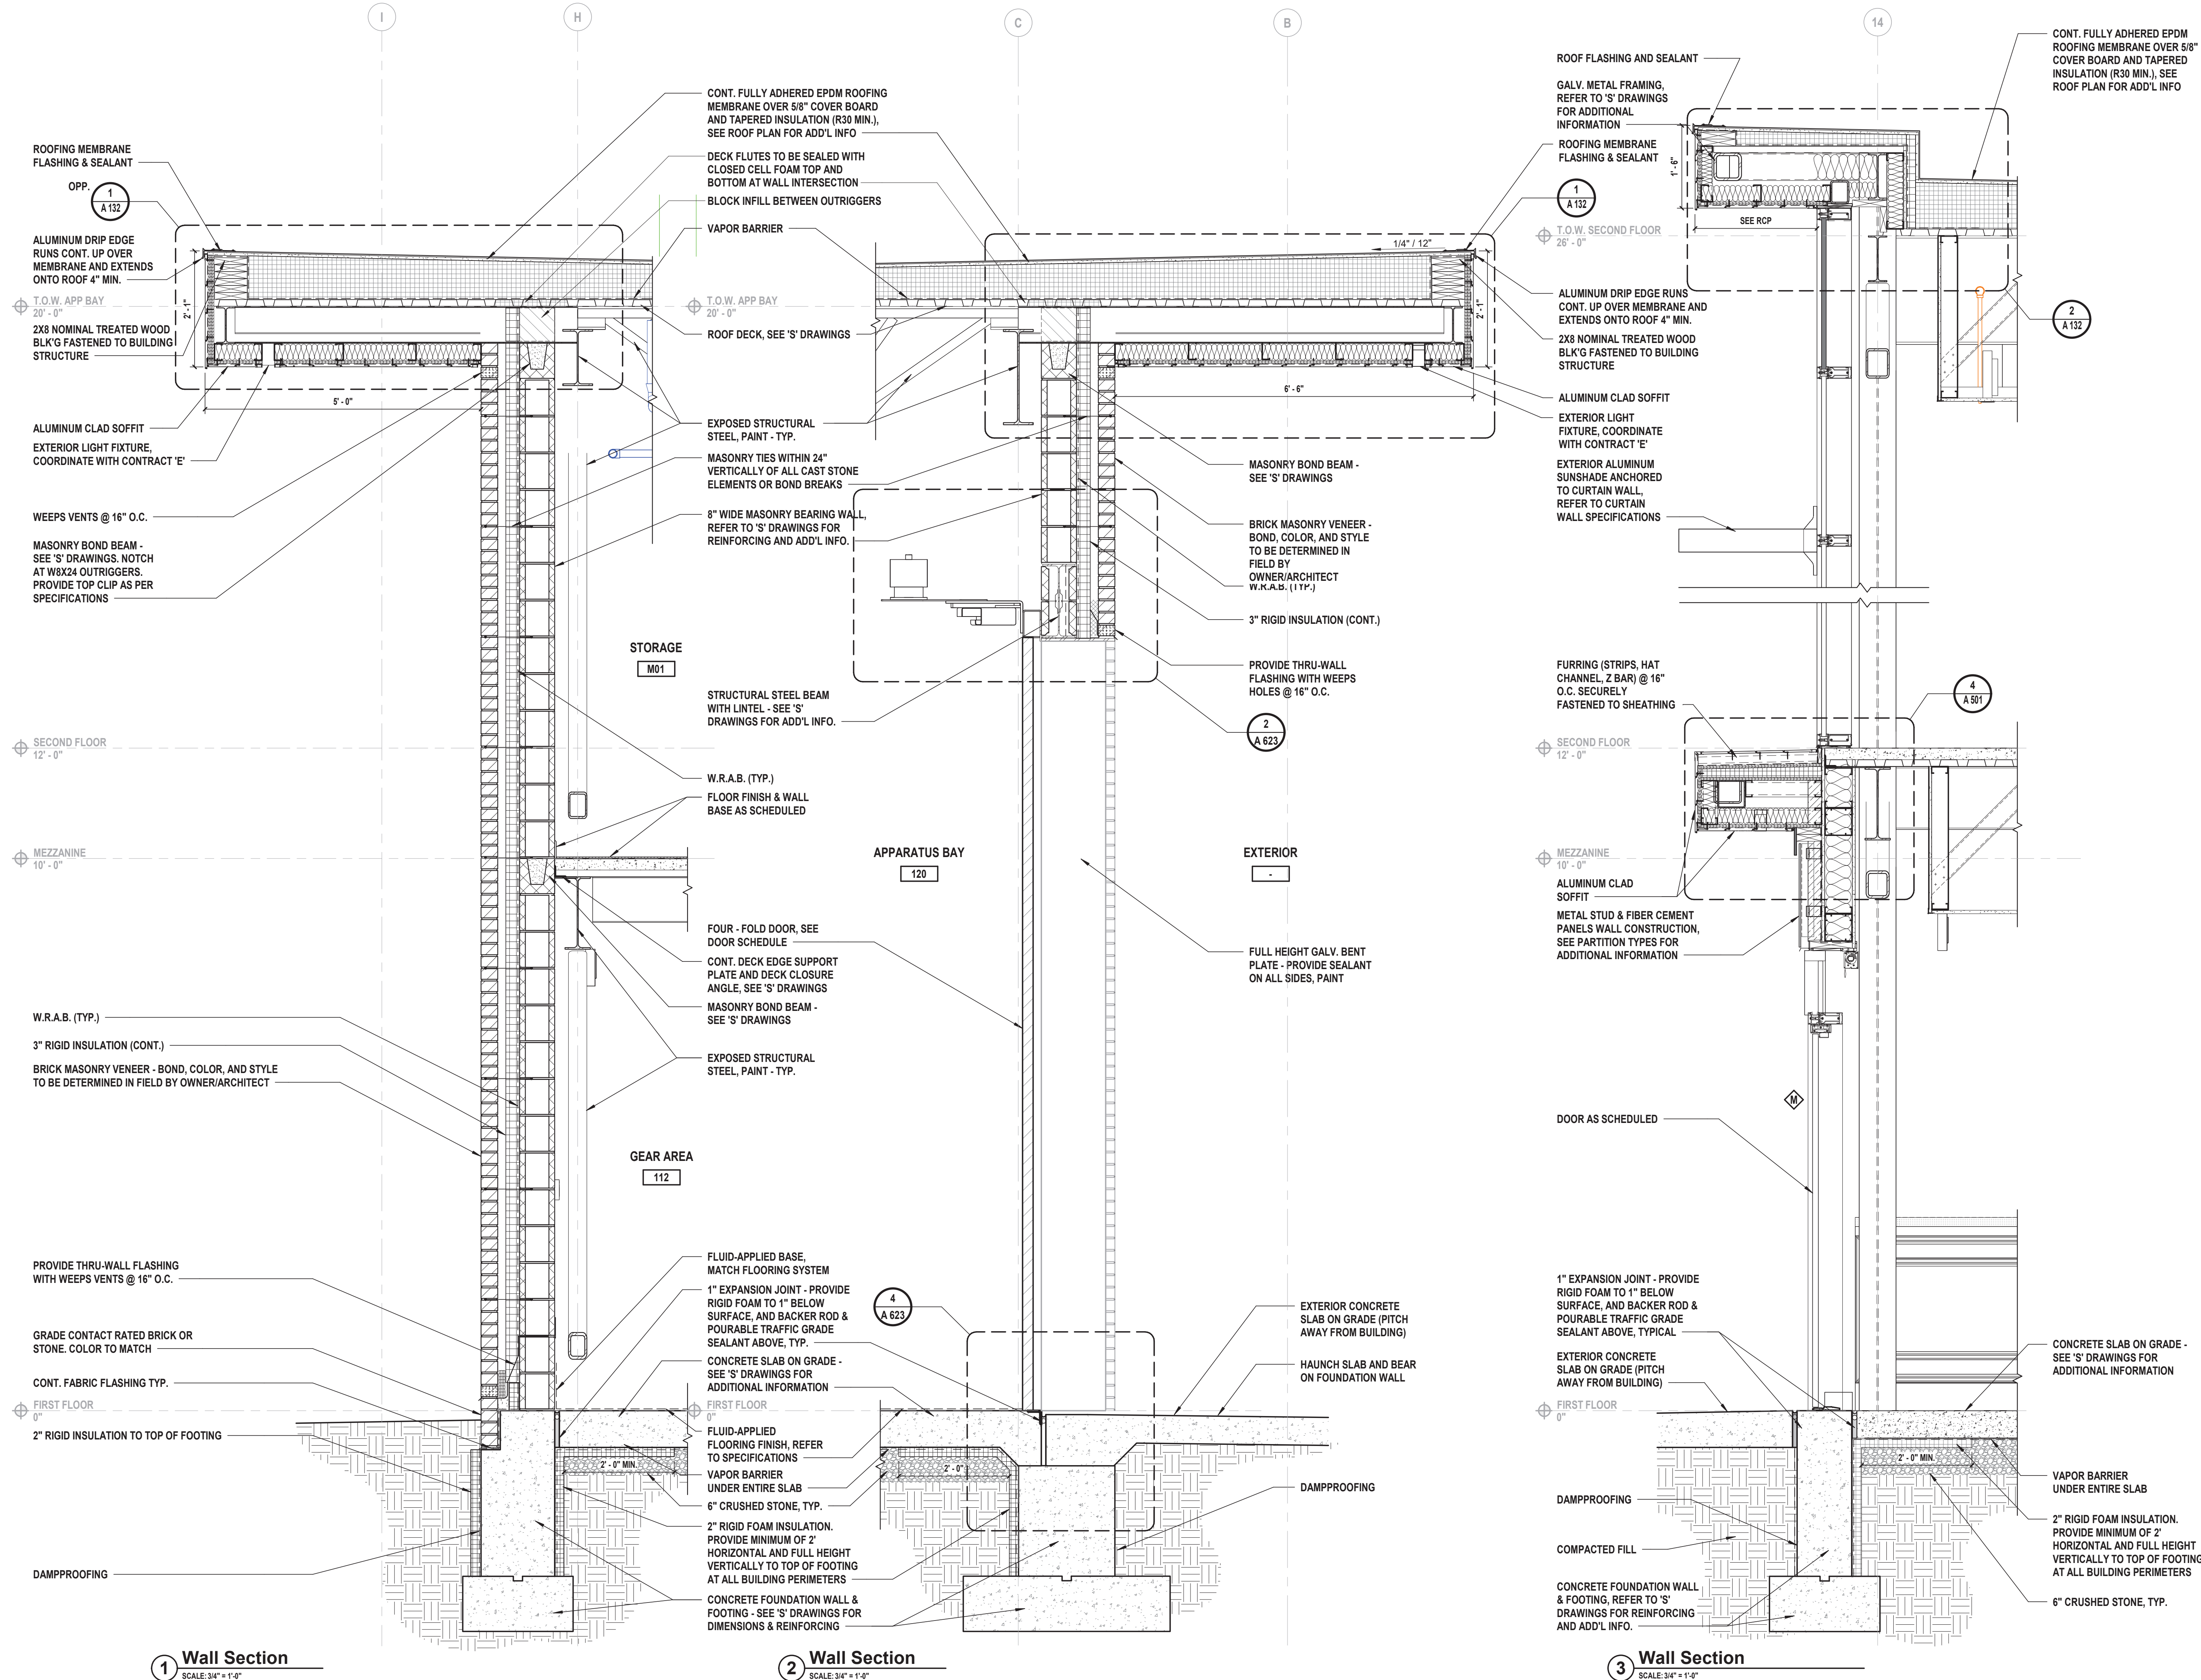

1 Wall Section

2 Wall Section
SCALE: 3/4" = 1'-0"

3 Wall Section

538 Broad Hollow Road, 4th Floor East
Melville, NY 11747
631.756.8000 • www.h2m.com
NY Architecture & Landscape Architecture: No Certificate Required
NY Engineering Certificate of Authorization No.: 0018178

CONSULTANTS:		

MARK	DATE	DESCRIPTION



10/31/2025

Exp. Date

PATRICK O. STONE, R.A.

NY PROFESSIONAL ARCHITECT LIC. NO. 039654

DESIGNED BY: DBS/RLG

DRAWN BY: ANK

CHECKED BY: DBS

REVIEWED BY: POS

PROJECT No: TRFD 2302

DATE: FEBRUARY 2025

SCALE: AS SHOWN

CLIENT

THIELLS
ROSEVILLE FIRE
DISTRICT

NEW 26-100 FIRE
HEADQUARTERS




65 W RAMAPO ROAD
GARNERVILLE, NY 10923

CONTRACT
CONTRACT G
GENERAL CONSTRUCTION


STATUS
FINAL BID DOCUMENT

SHEET TITLE
ENLARGED STAIR 'A' PLAN AND
SECTIONS


DRAWING No.
A 400.00

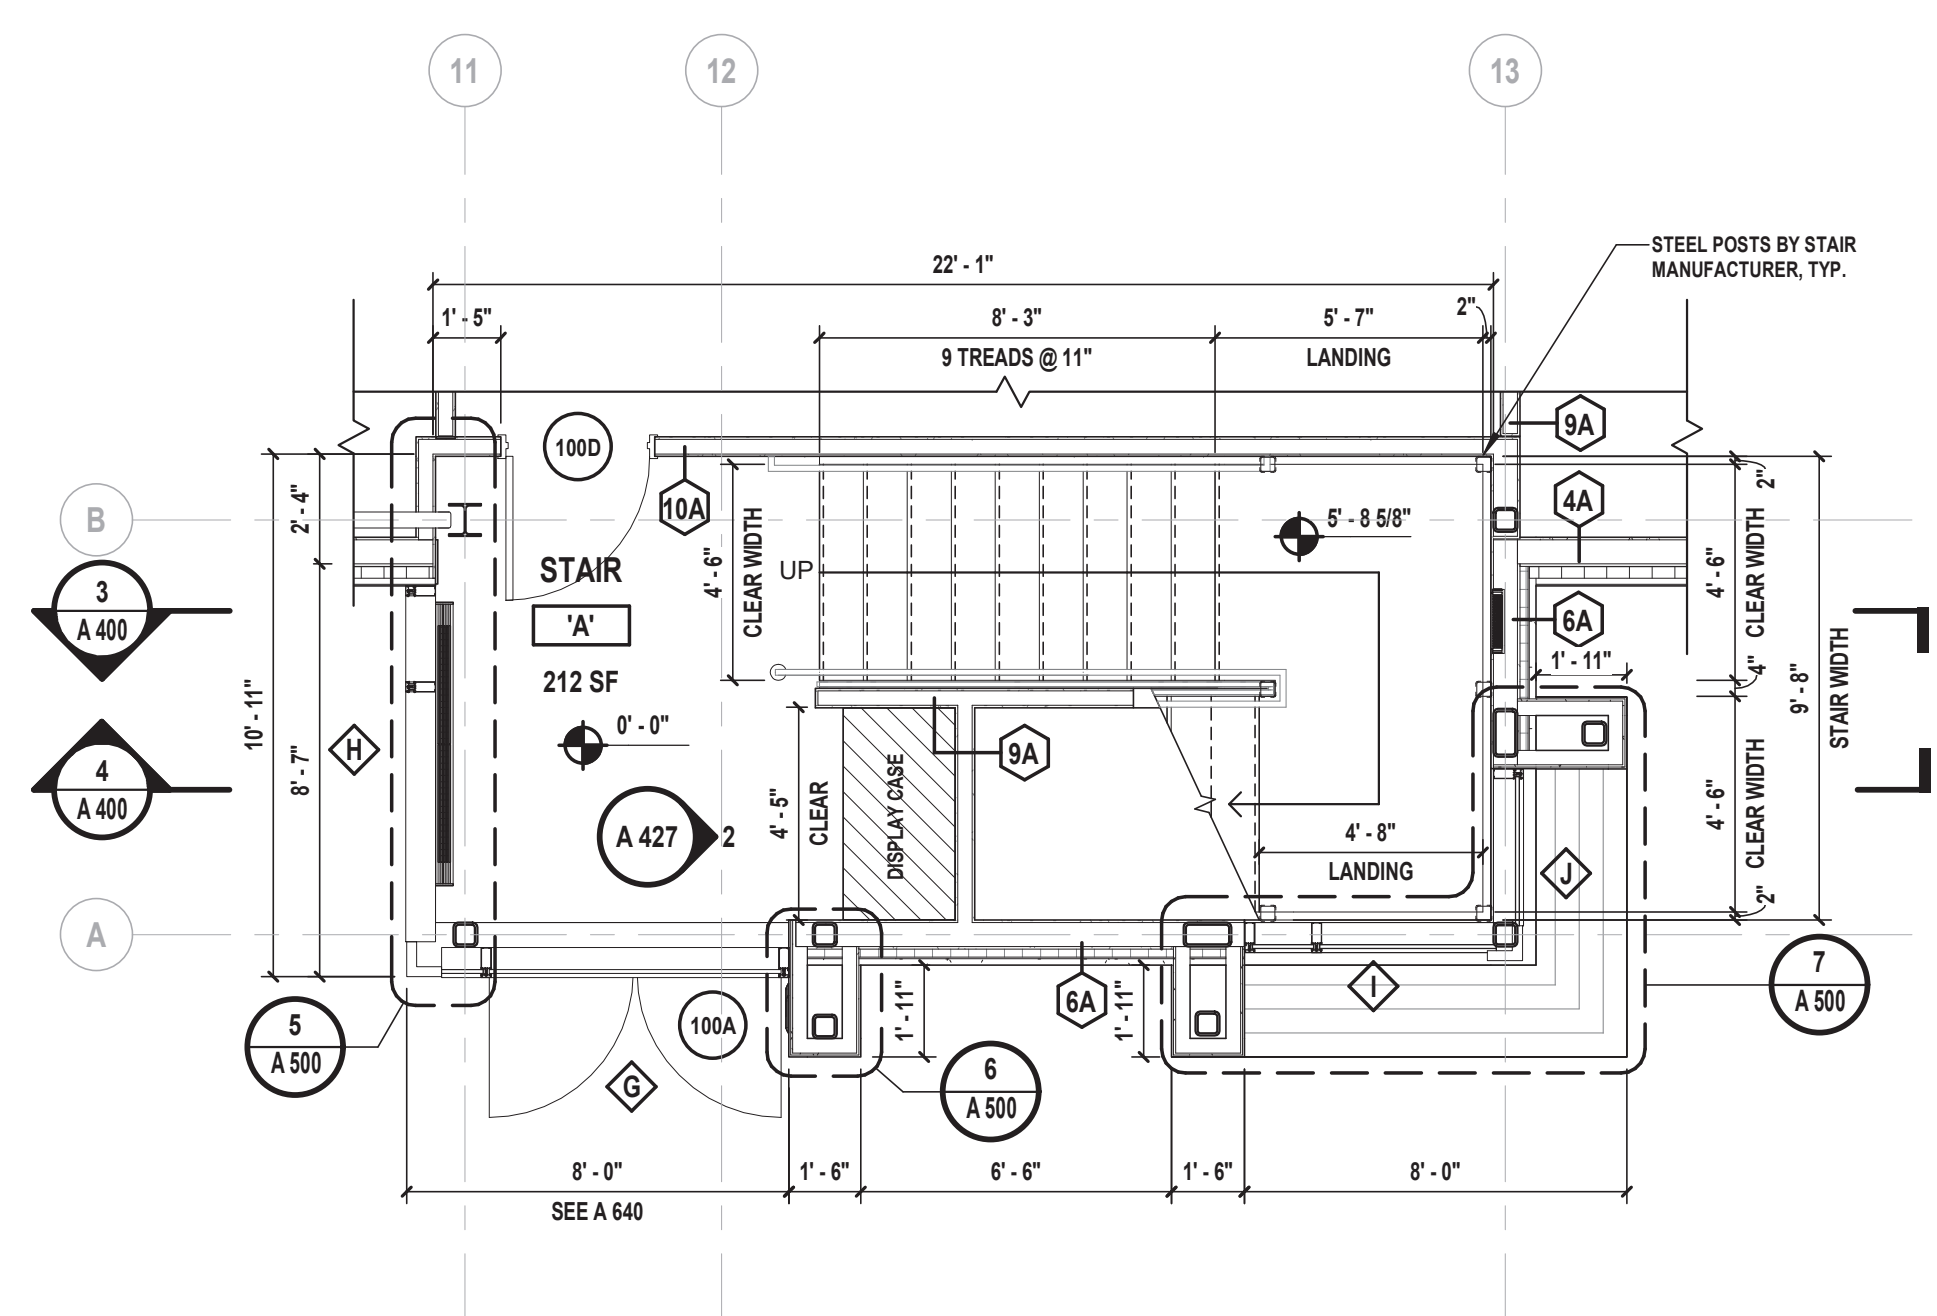


1 Enlarged First Floor Plan - Stair 'A'
SCALE: 1/4" = 1'-0"

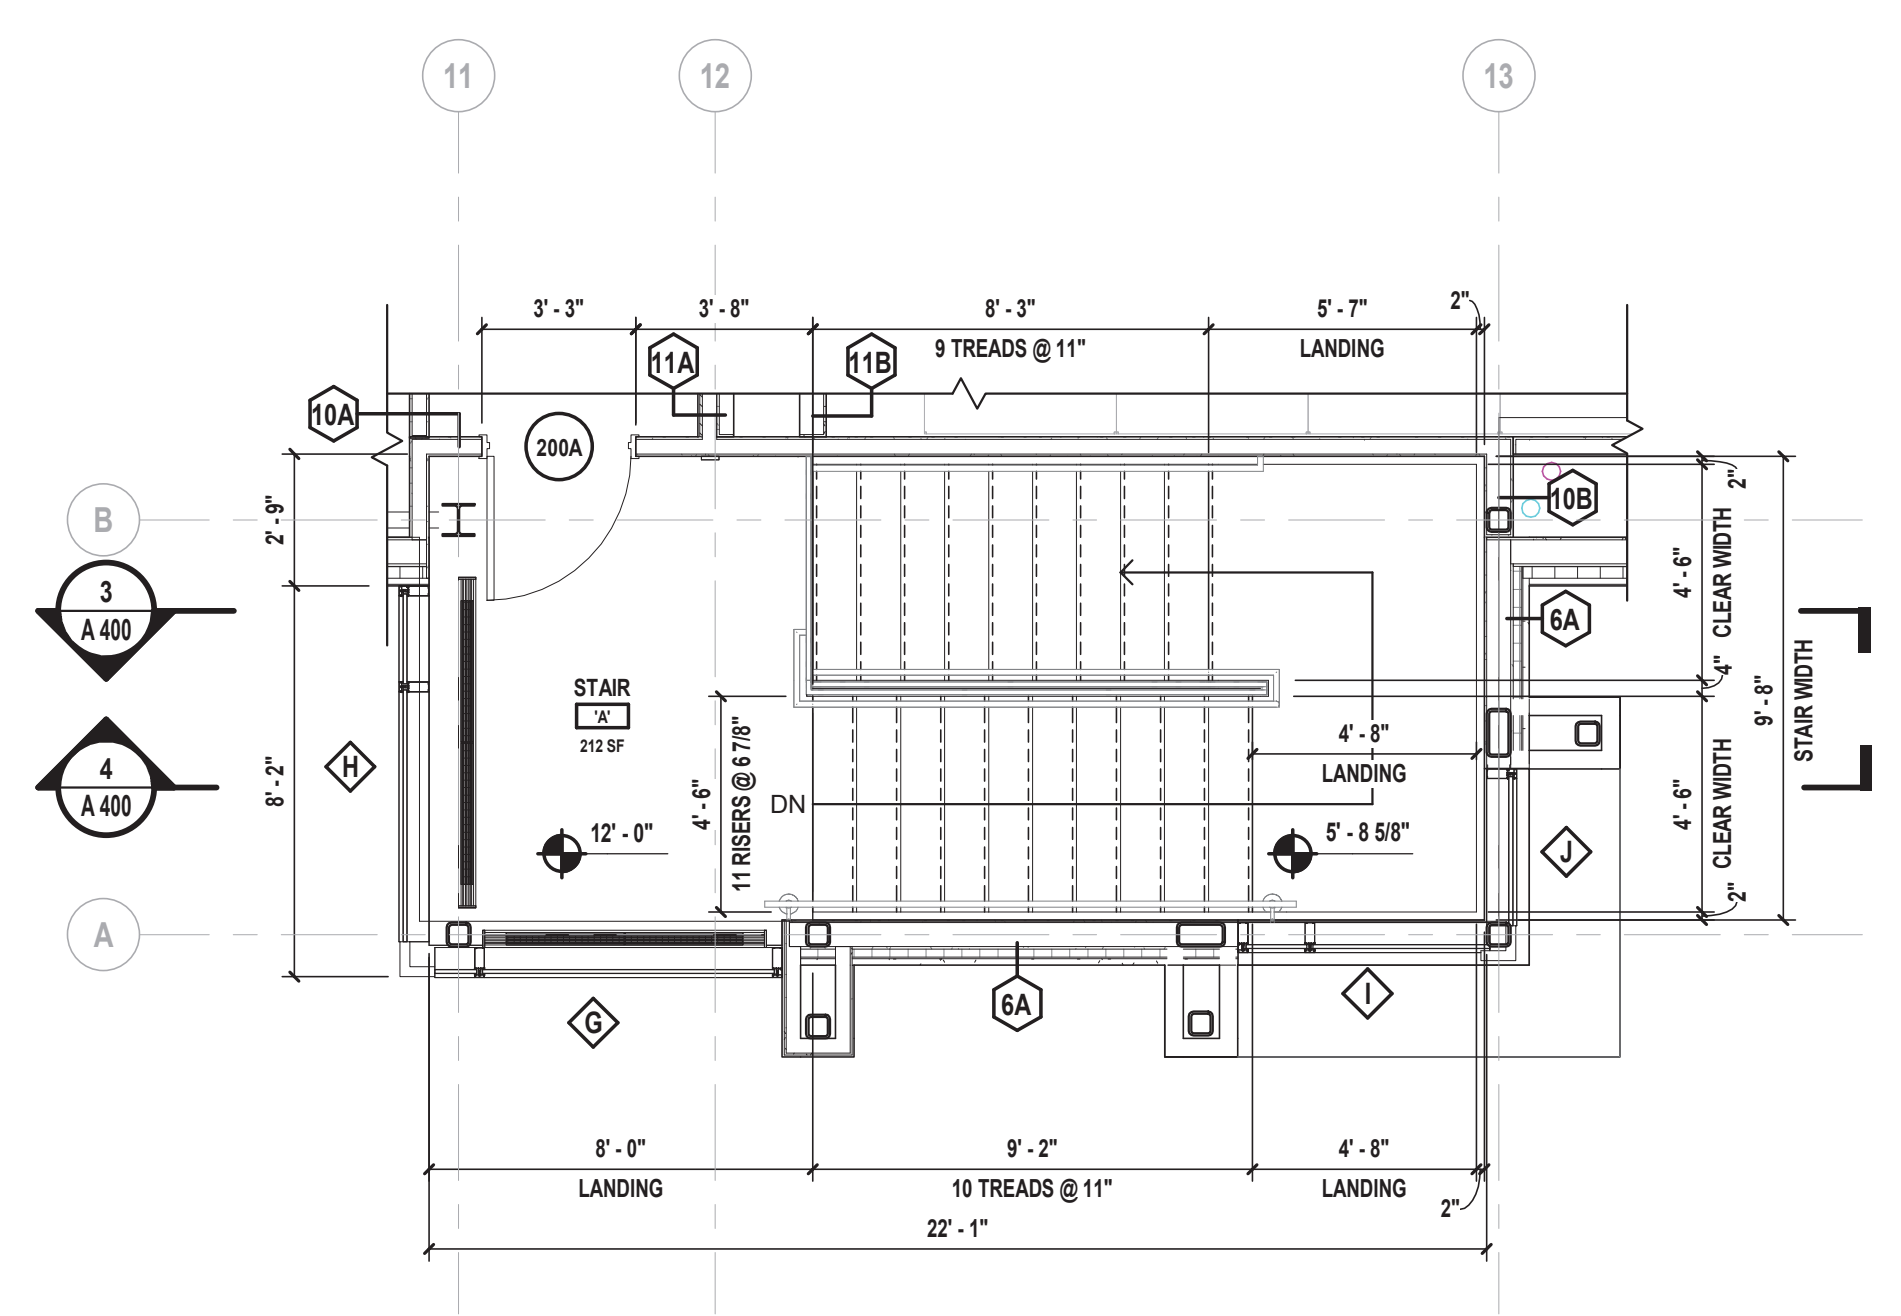


2 Enlarged Second Floor Plan - Stair 'A'
SCALE: 1/4" = 1'-0"

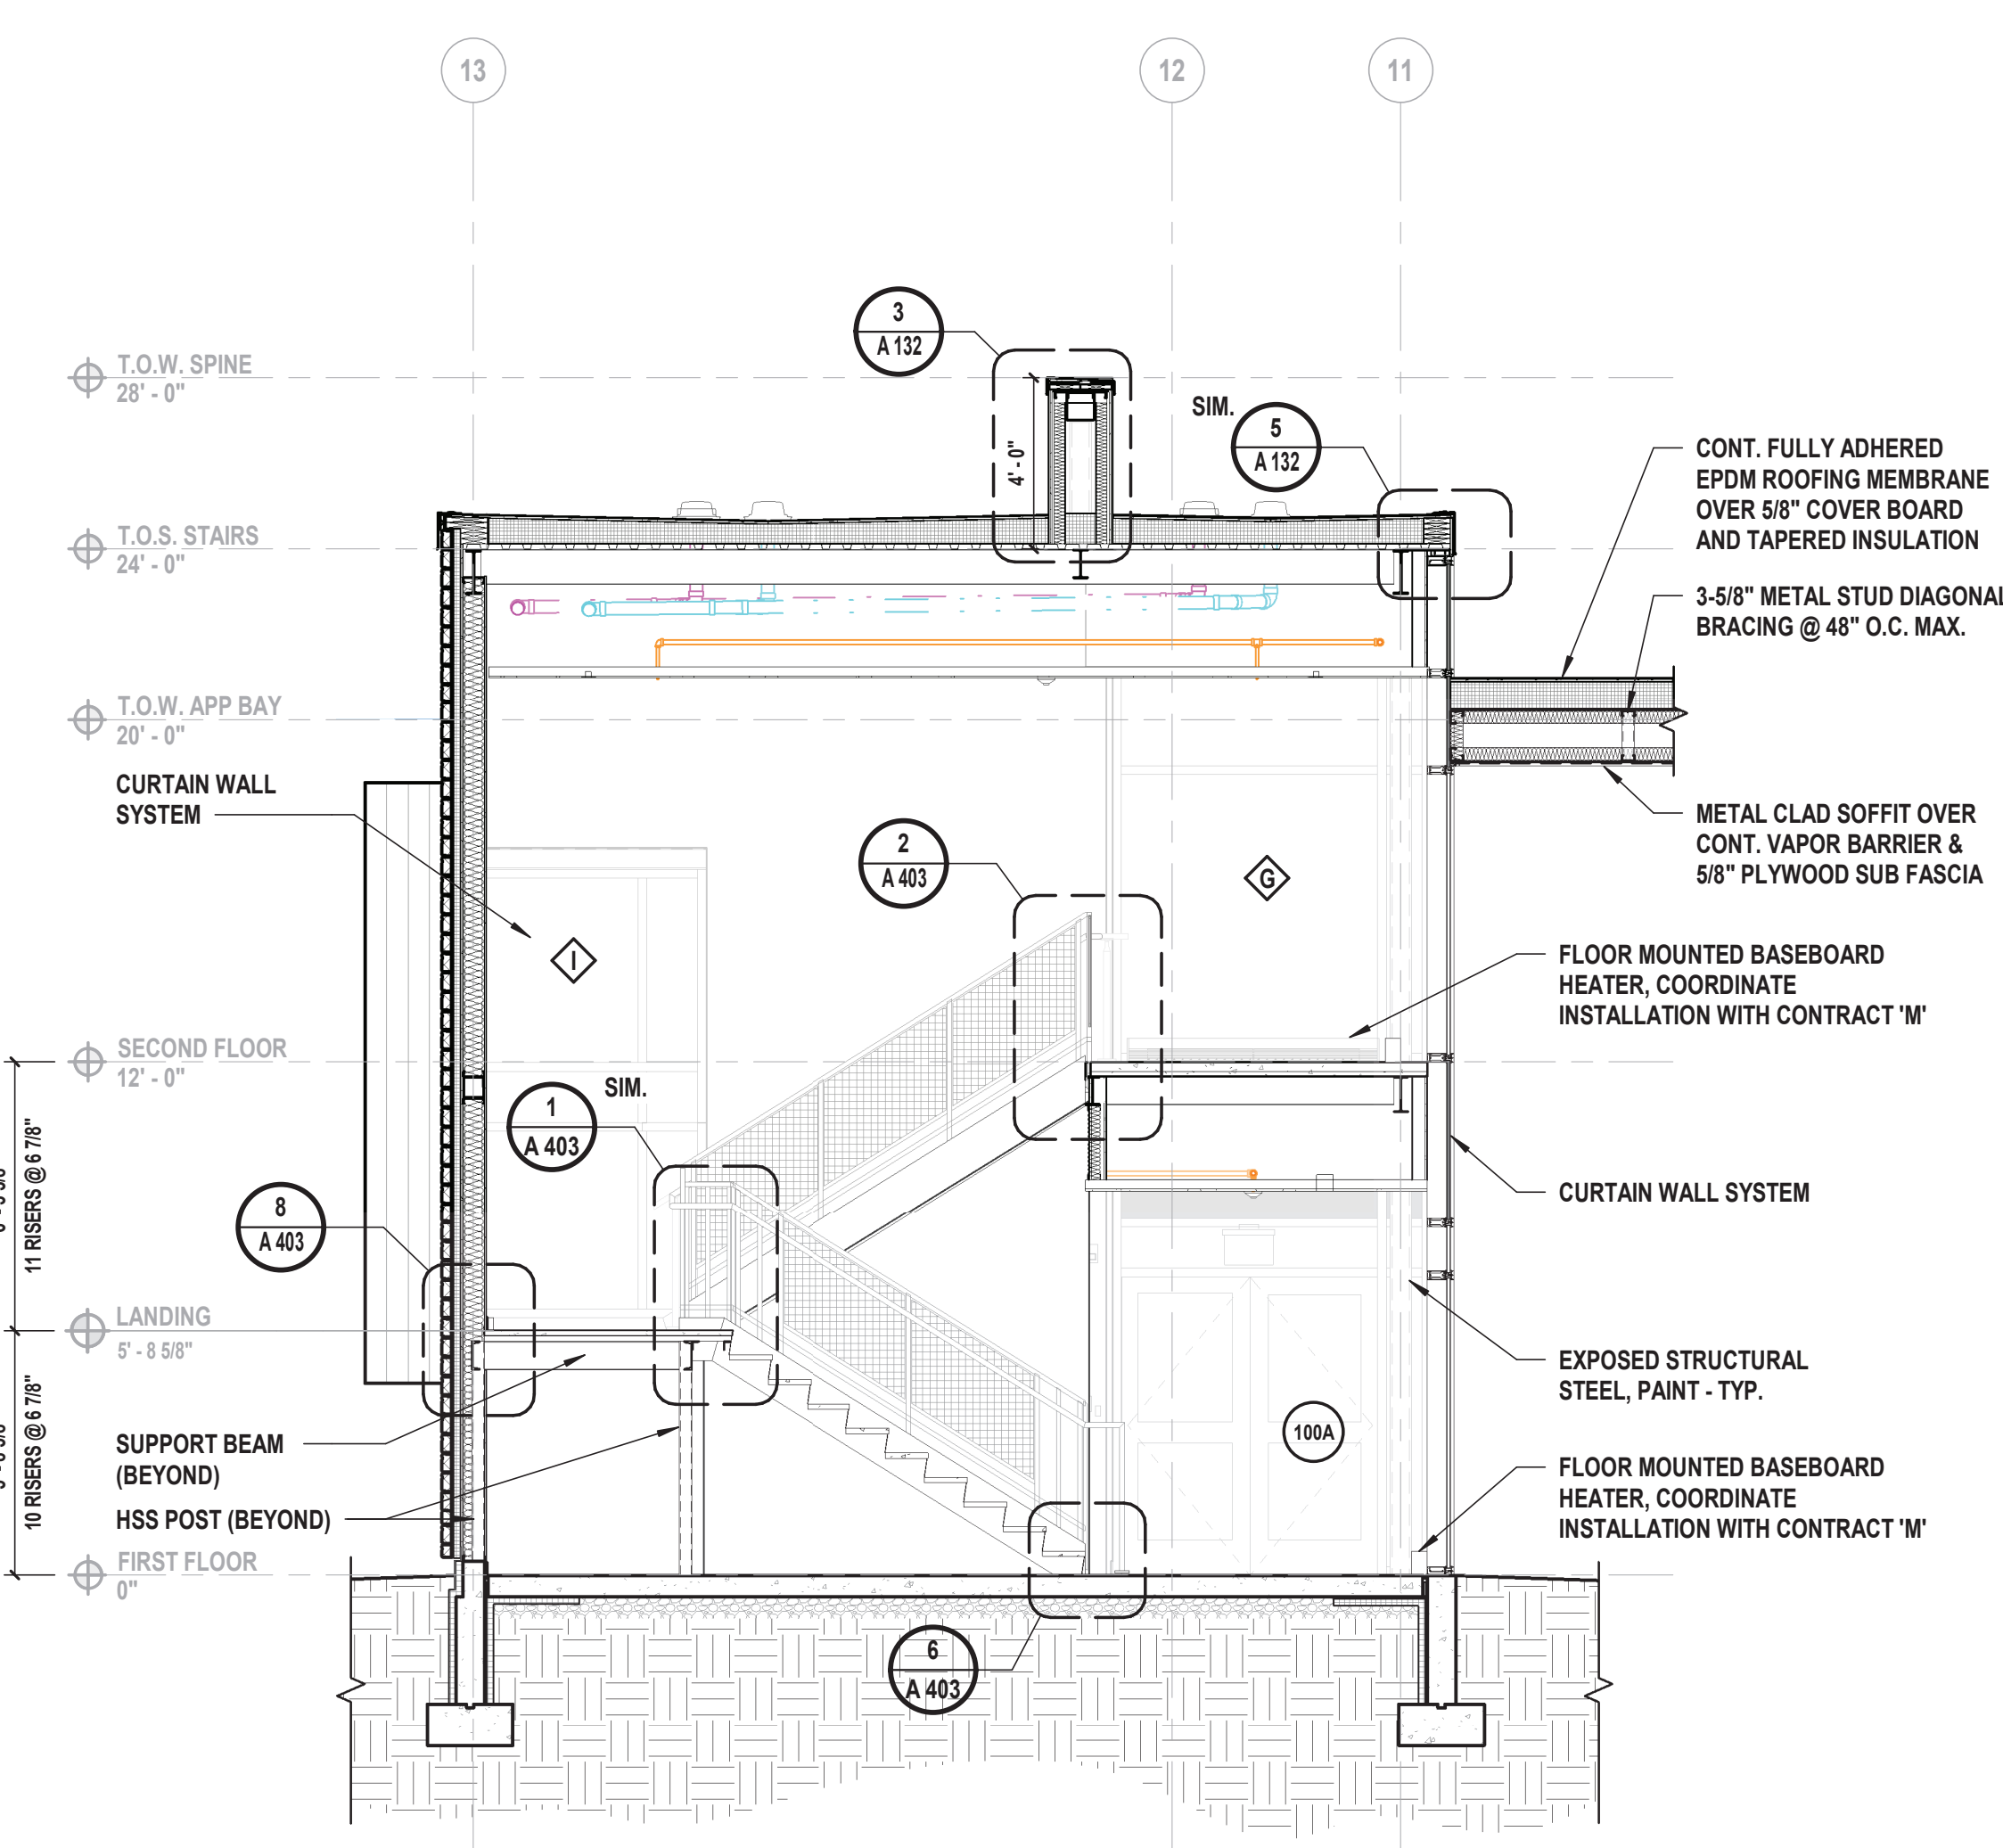

3 Stair 'A' Section
SCALE: 1/4" = 1'-0"

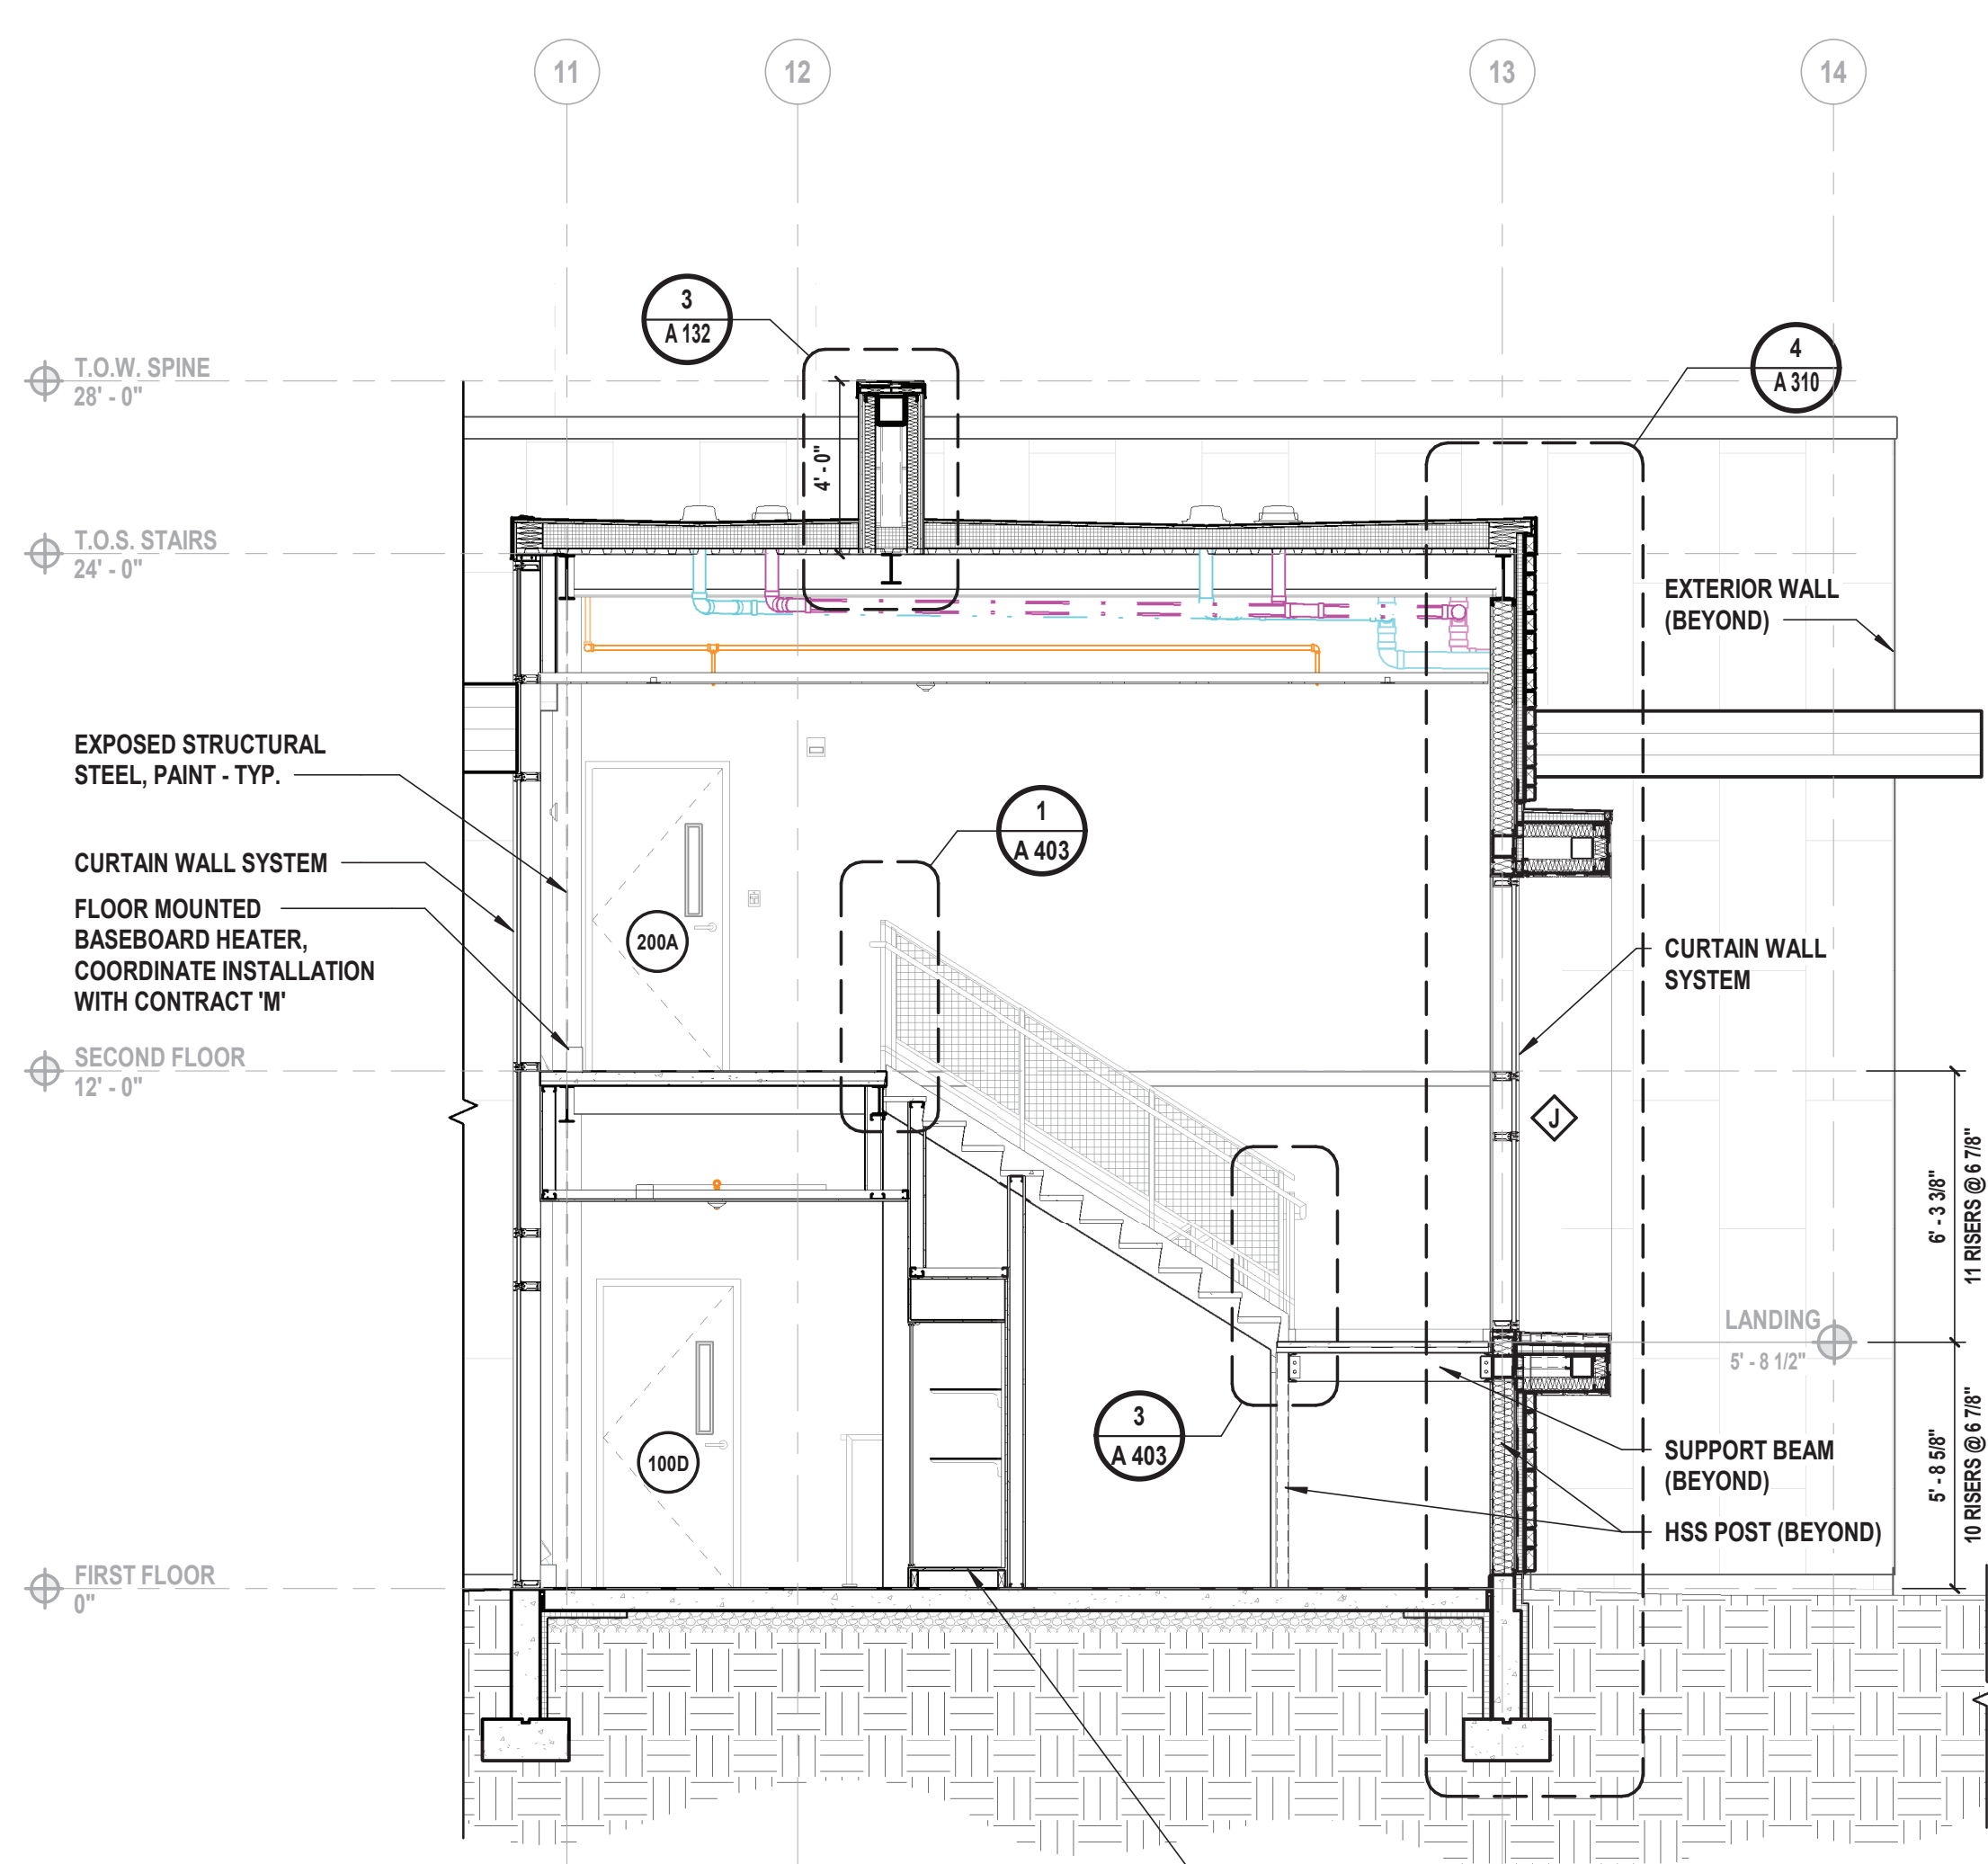

4 Stair 'A' Section
SCALE: 1/4" = 1'-0"

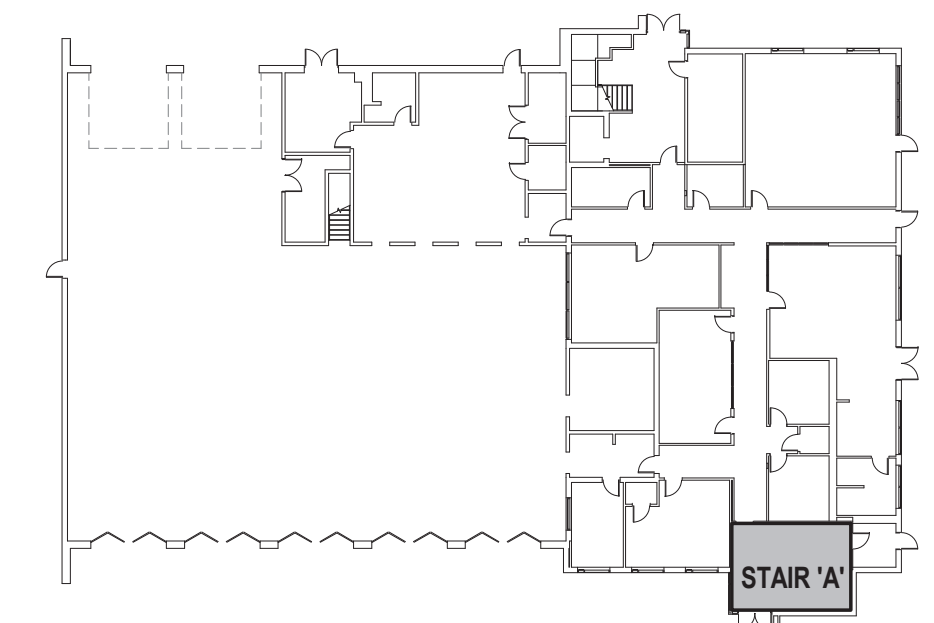

First Floor Key Plan
SCALE: NTS

CONSULTANTS:		

MARK	DATE	DESCRIPTION

REGISTERED ARCHITECT
PATRICK O. STONE
STATE OF NEW YORK
039654


PATRICK O. STONE, R.A.
NY PROFESSIONAL ARCHITECT LIC. NO. 039654

10/31/2025
Exp. Date

*IN ACCORDANCE WITH ARTICLE 145, SECTION 1209 OF THE NYS EDUCATION LAW,
ALTAUTION OF THIS DOCUMENT EXCEPT BY A LICENSED PROFESSIONAL IS ILLEGAL.

DESIGNED BY:	DRAWN BY:	CHECKED BY:	REVIEWED BY:
DBS/RLG	ANK	DBS	POS
PROJECT No:	DATE:	SCALE:	AS SHOWN
TRFD 2302	FEBRUARY 2025		

CLIENT

THIELLS
ROSEVILLE FIRE
DISTRICT

NEW 26-100 FIRE
HEADQUARTERS



65 W RAMAPO ROAD
GARNERVILLE, NY 10923

CONTRACT

CONTRACT G
GENERAL CONSTRUCTION

STATUS


FINAL BID DOCUMENT

SHEET TITLE


ENLARGED STAIR 'B' PLANS AND
SECTIONS

DRAWING No.


A 401.00

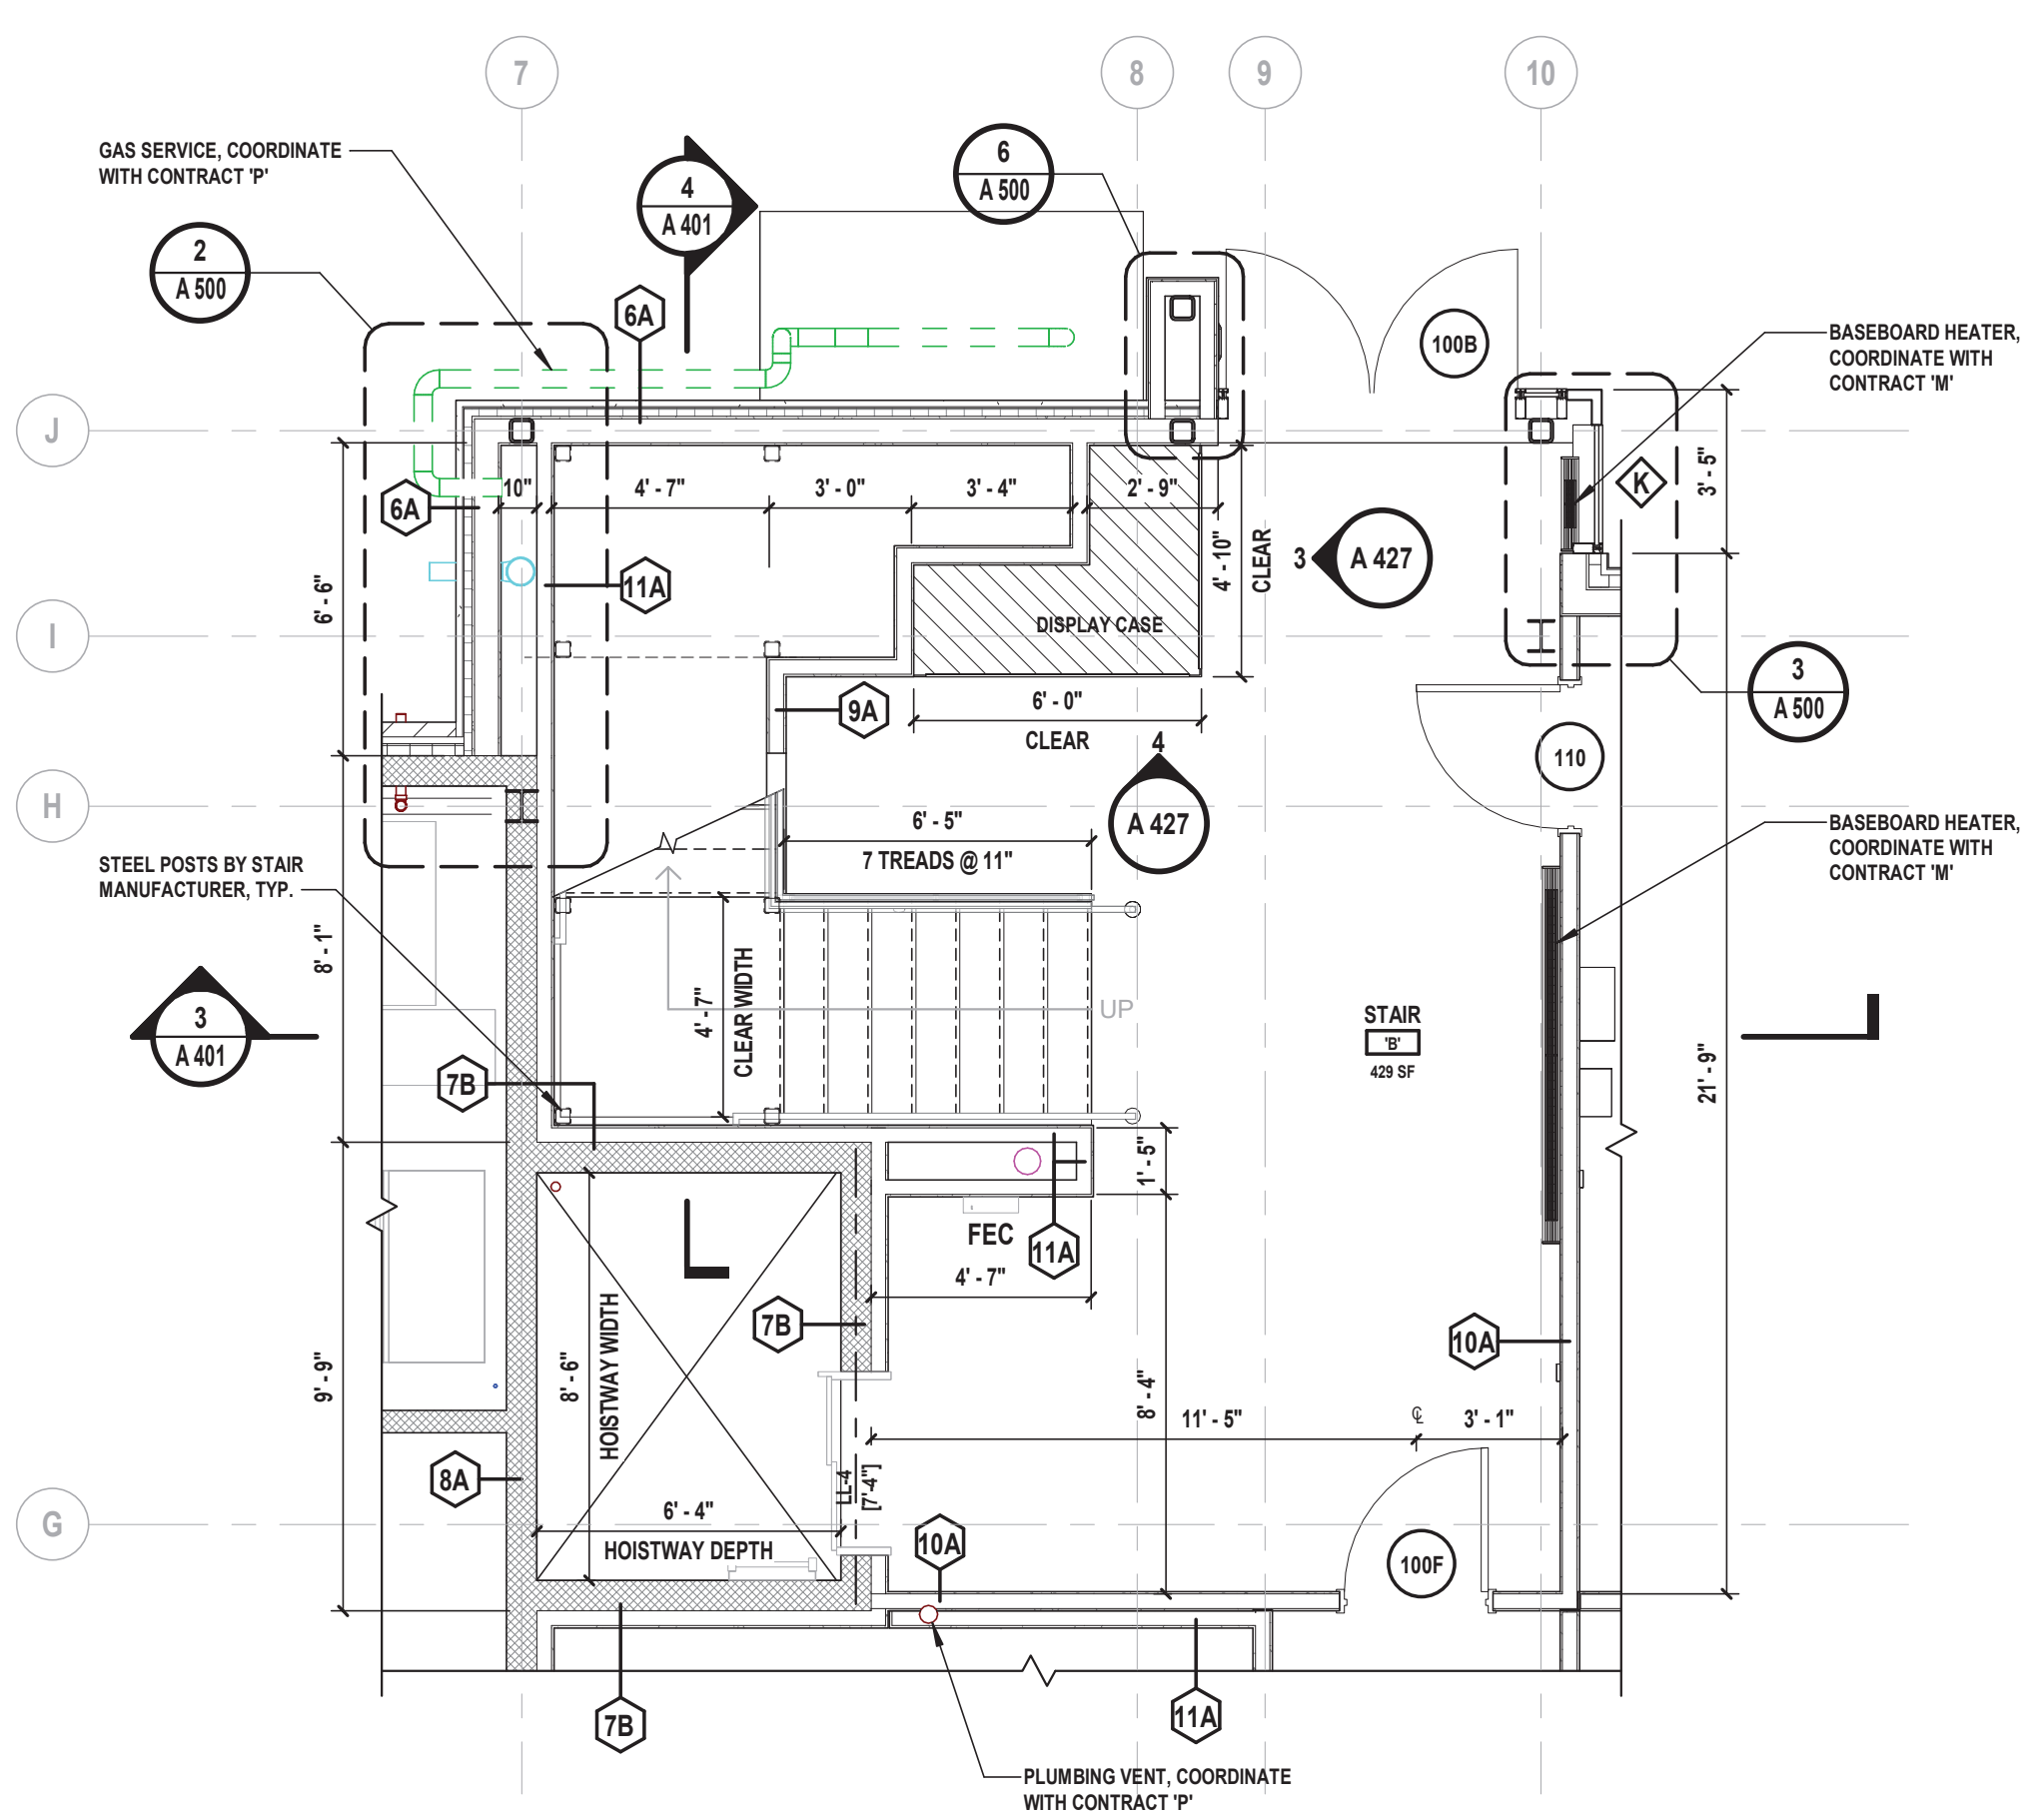


1 Enlarged First Floor Plan - Stair 'B'
SCALE: 1/4" = 1'-0"

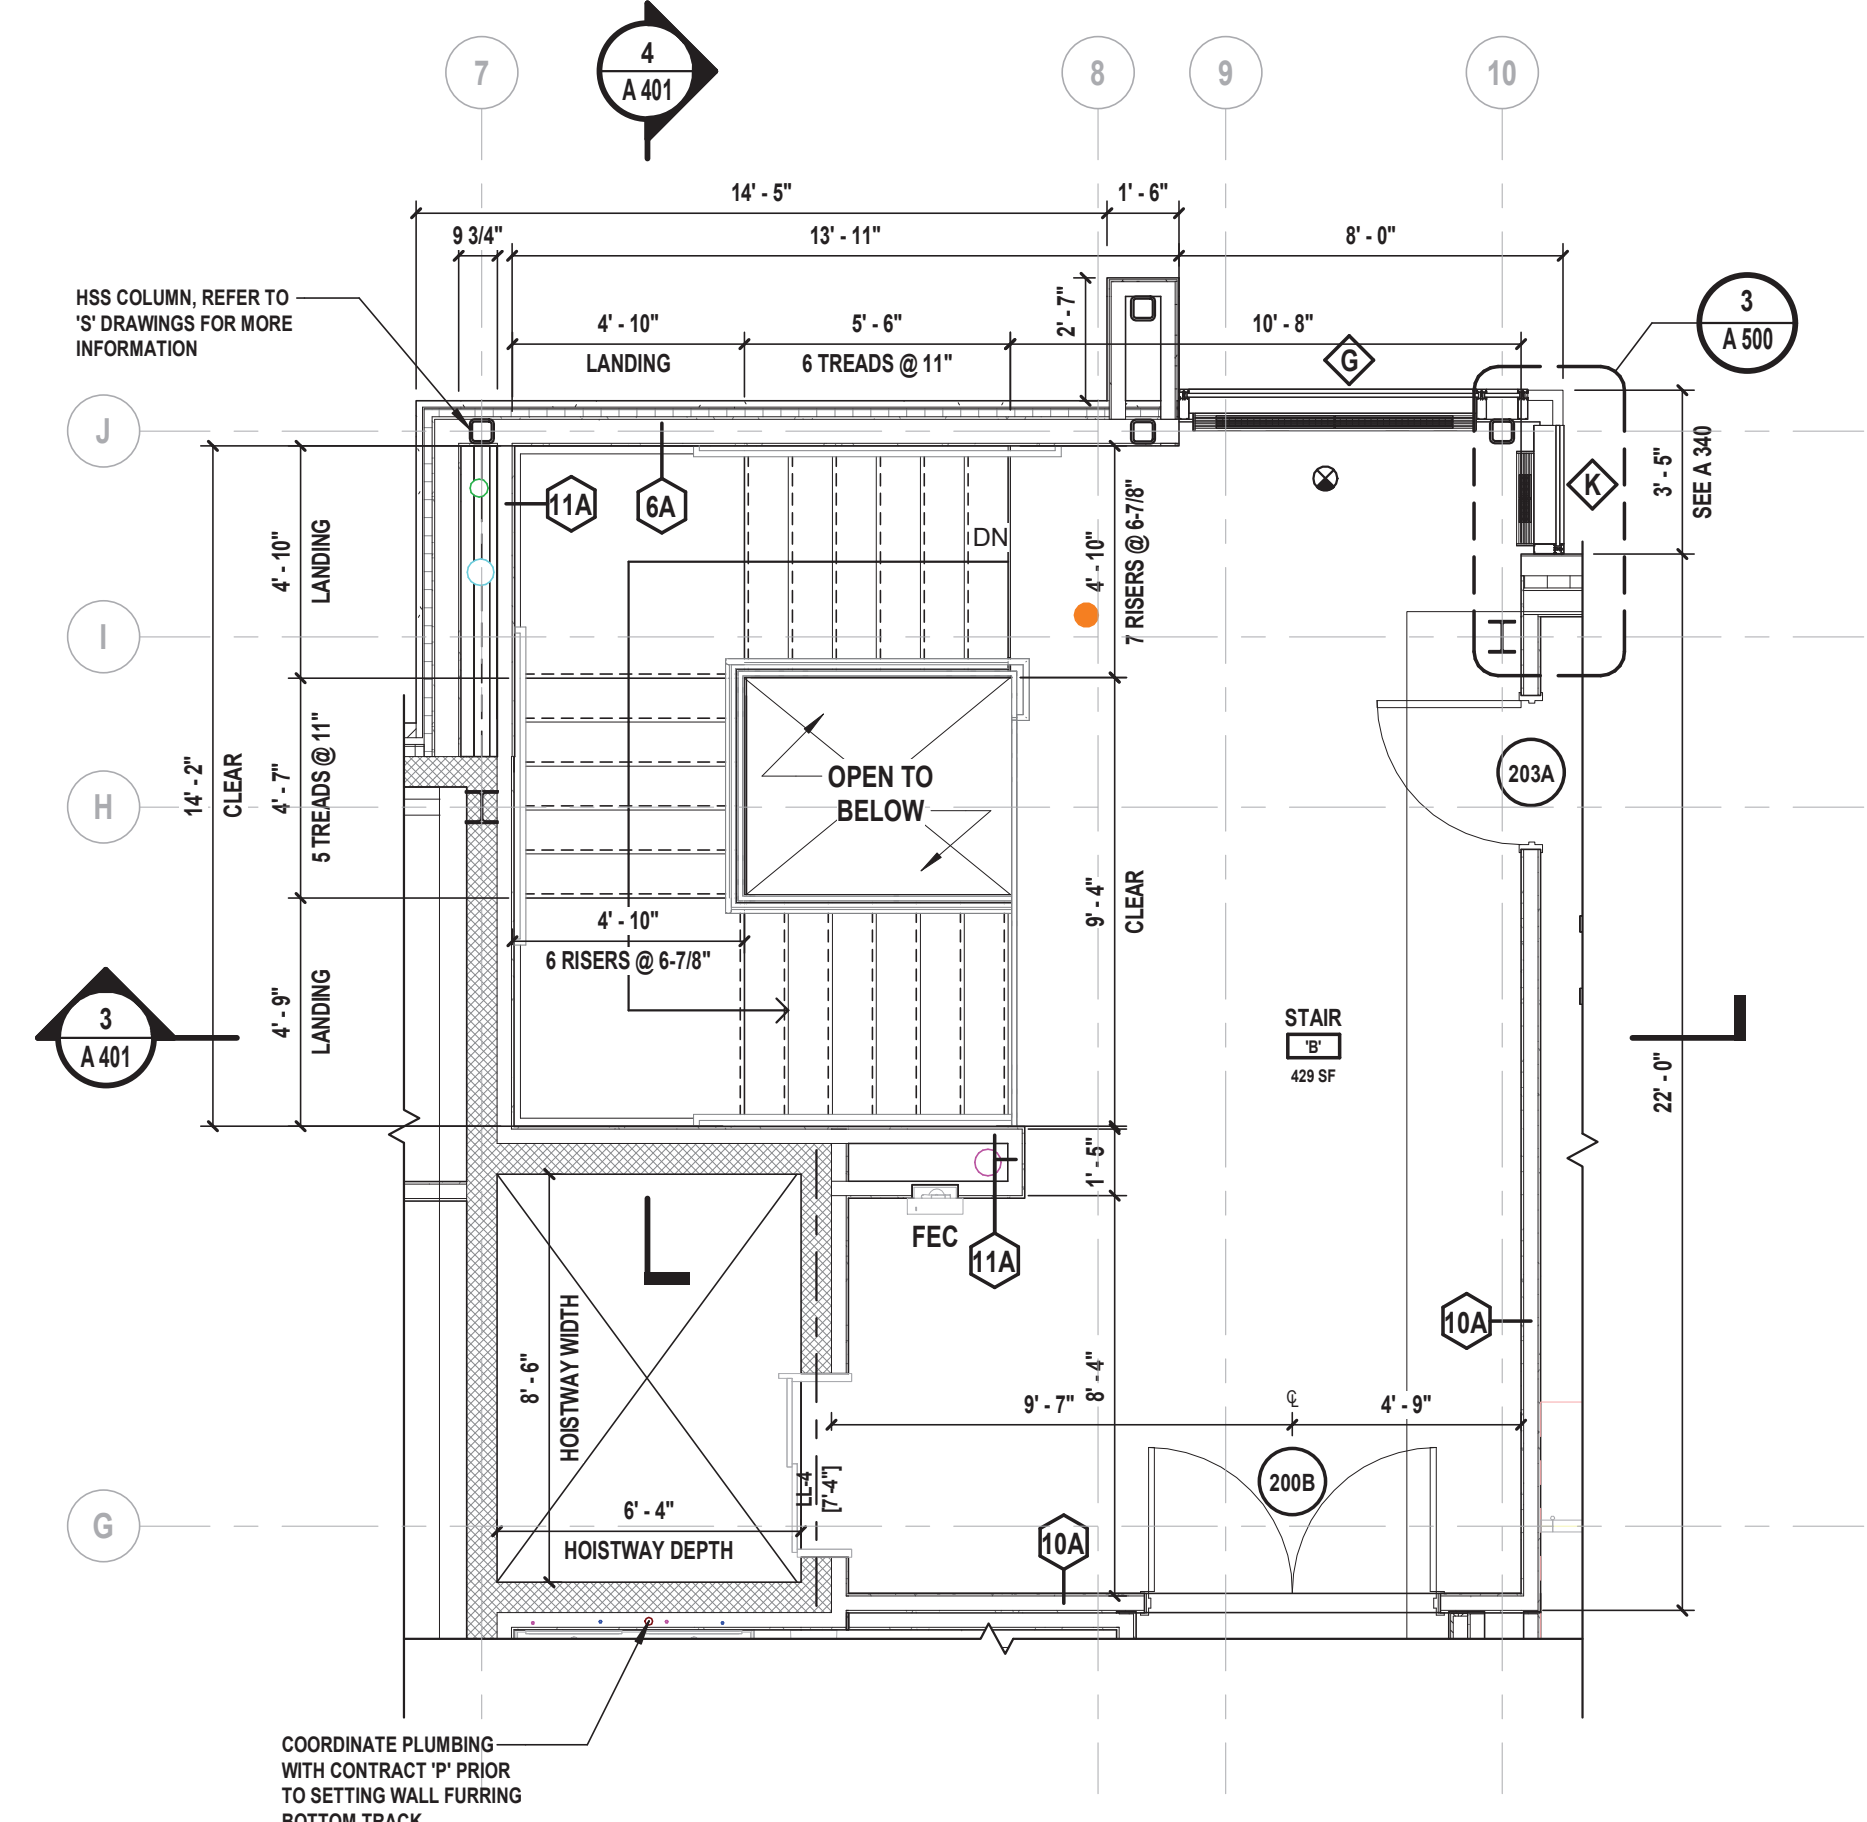


2 Enlarged Second Floor Plan - Stair 'B'
SCALE: 1/4" = 1'-0"

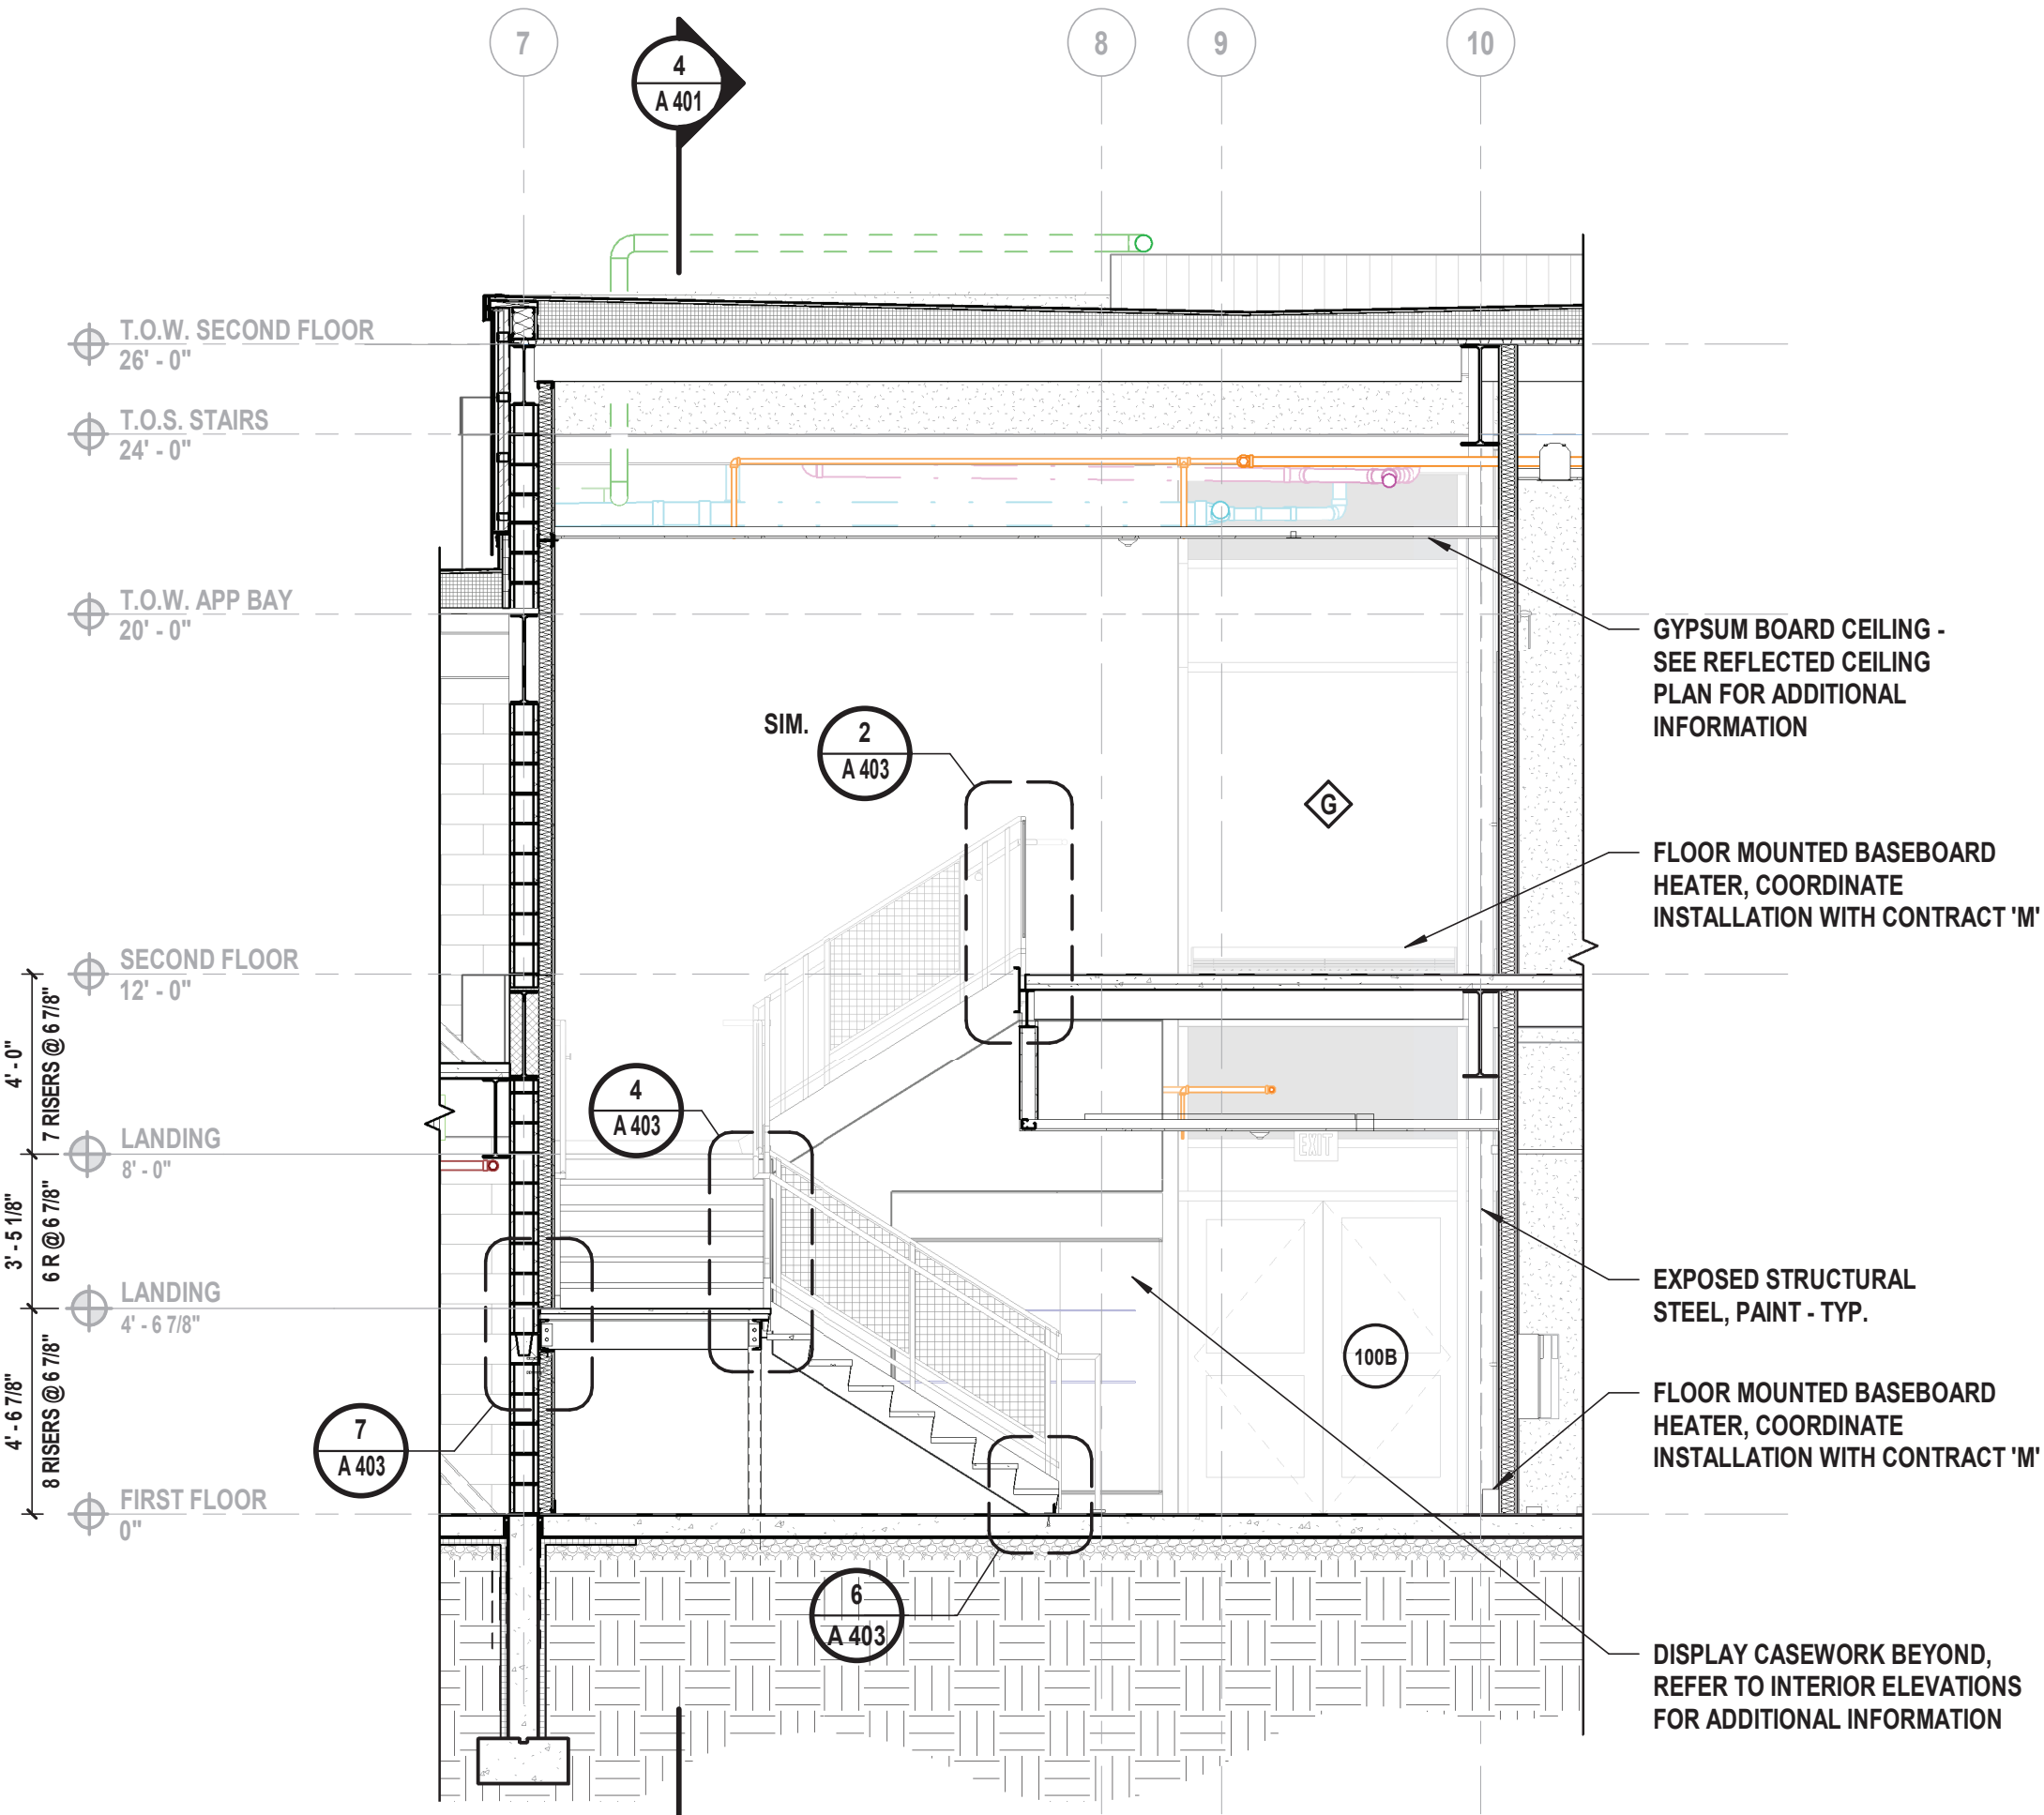


3 Stair 'B' Section
SCALE: 1/4" = 1'-0"

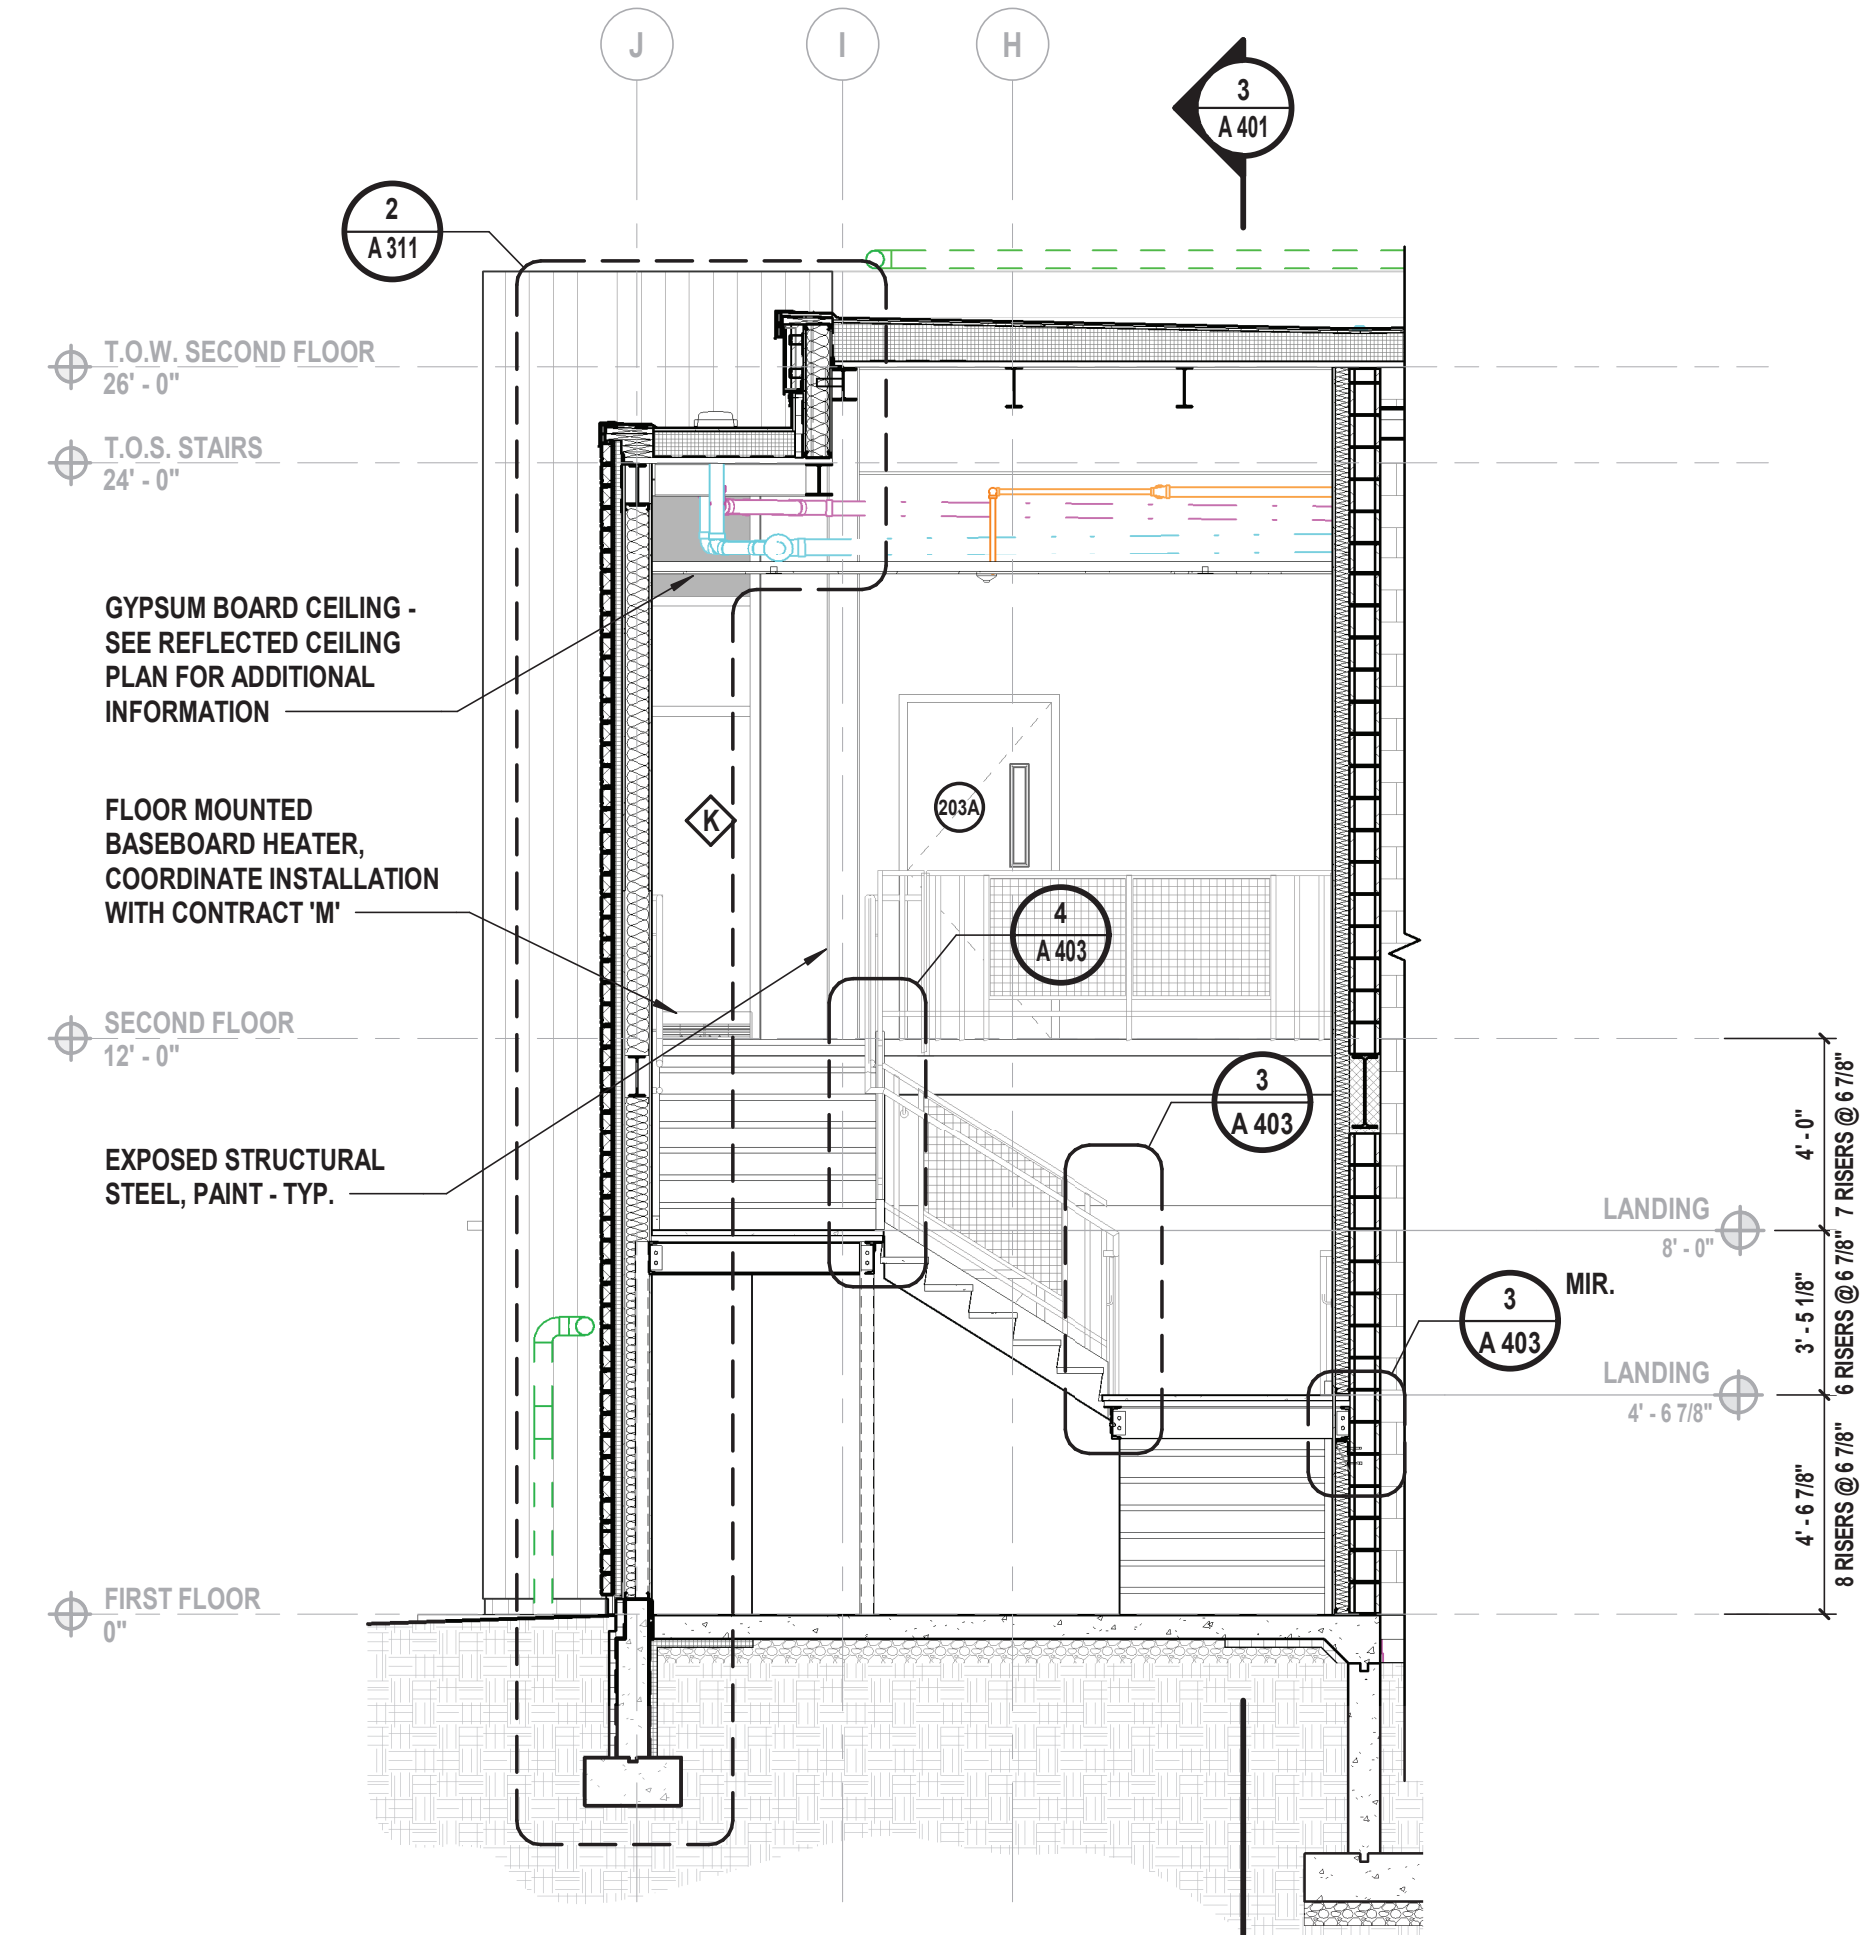


4 Stair 'B' Section
SCALE: 1/4" = 1'-0"

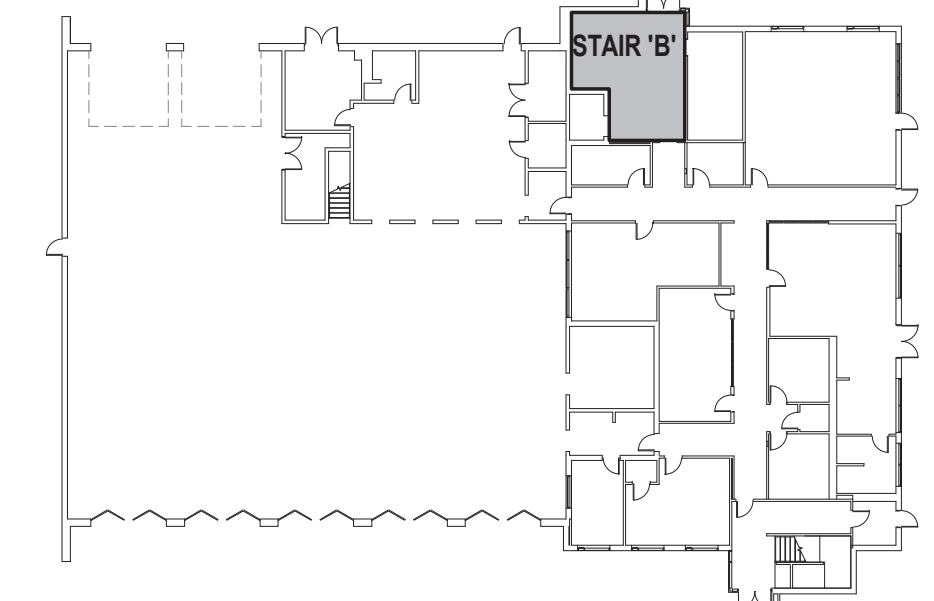


First Floor Key Plan
SCALE: NTS

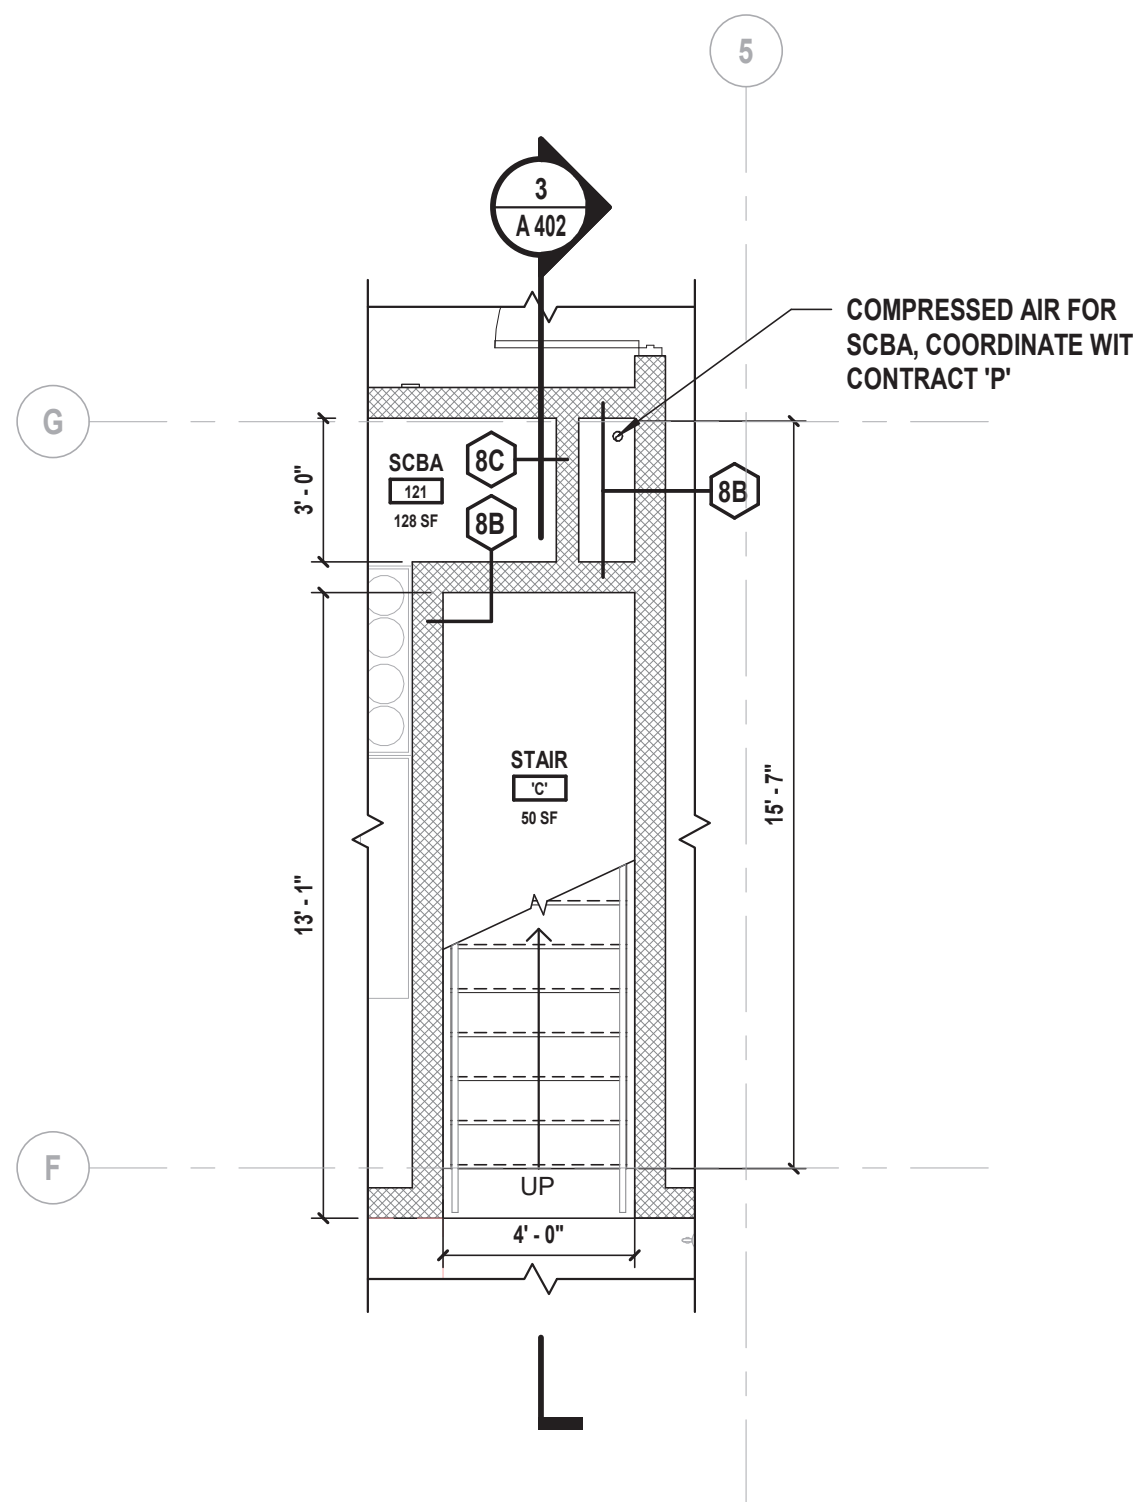


1 Enlarged First Floor Plan - Stair 'C'
SCALE: 1/4" = 1'-0"

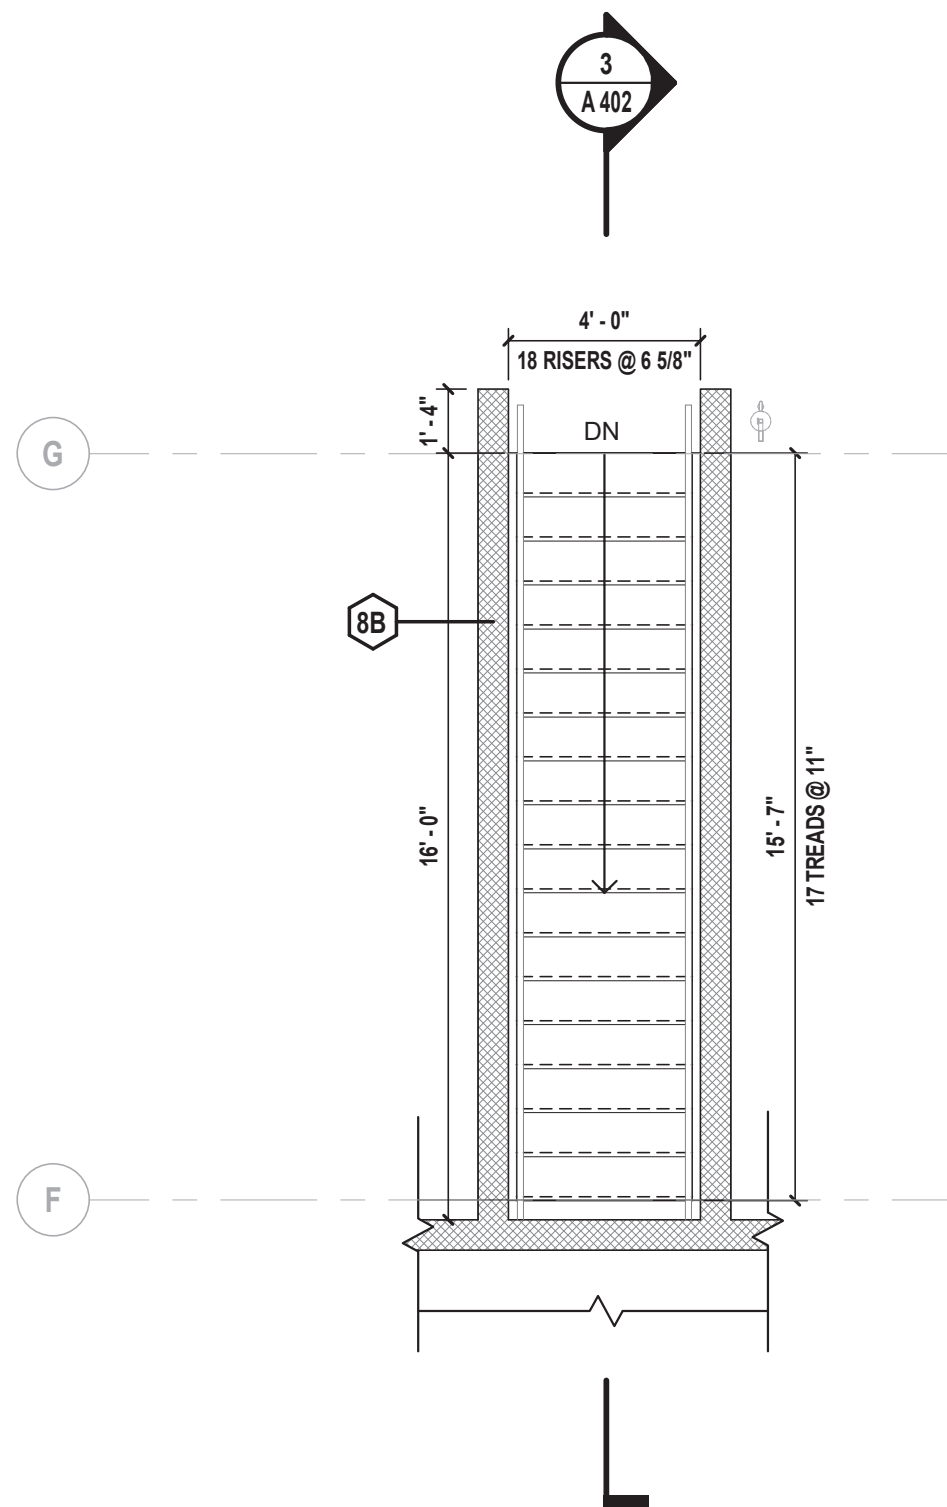


2 Enlarged Mezzanine Plan - Stair 'C'
SCALE: 1/4" = 1'-0"

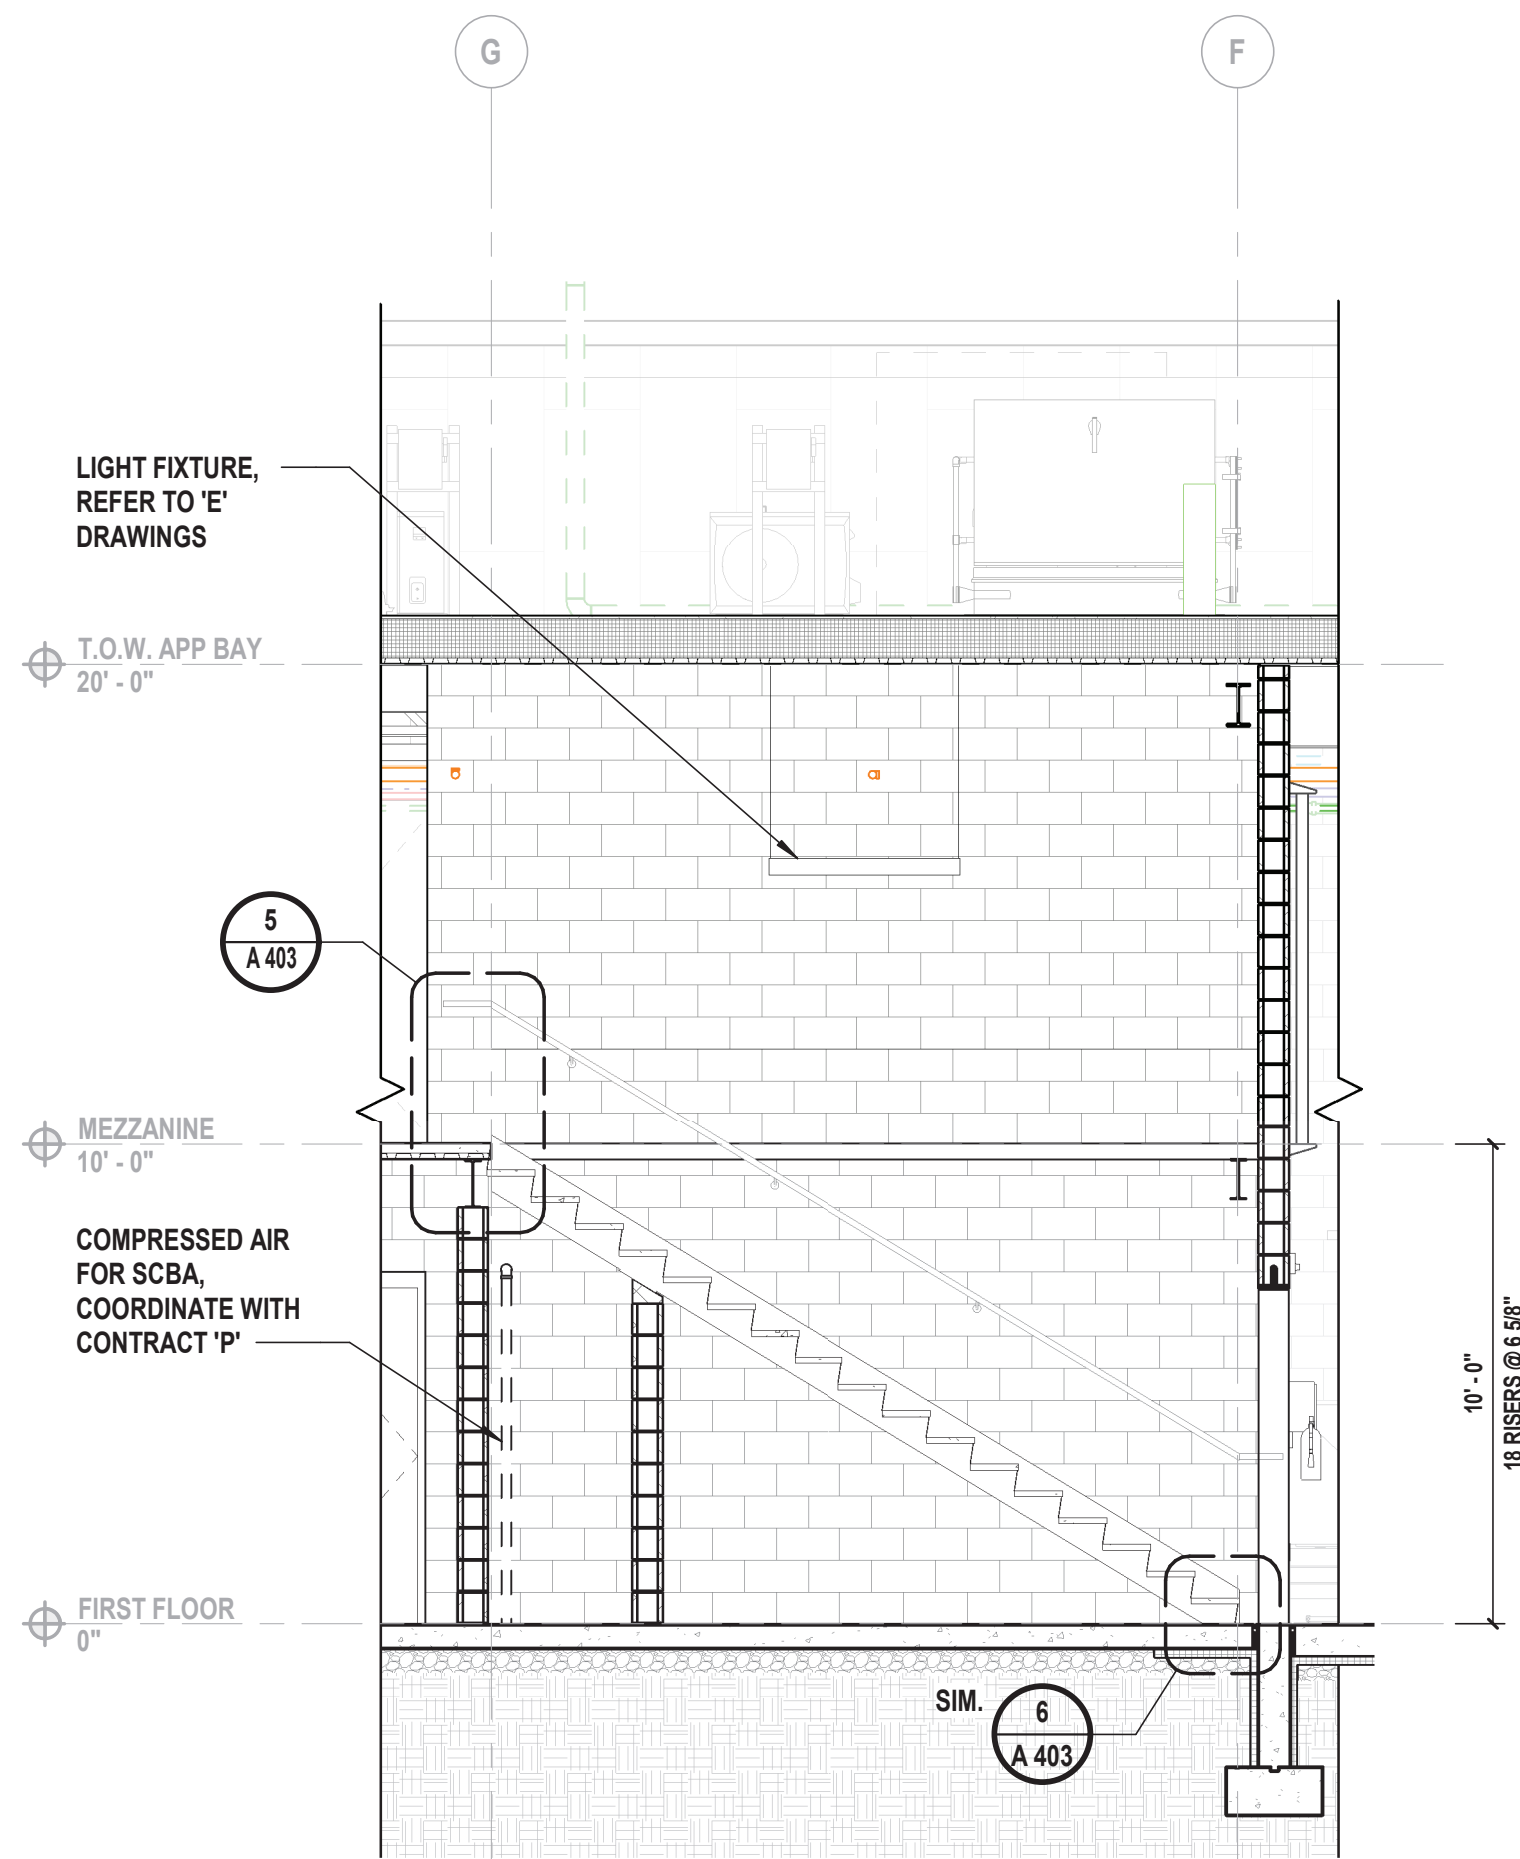

3 Stair 'C' Section
SCALE: 1/4" = 1'-0"

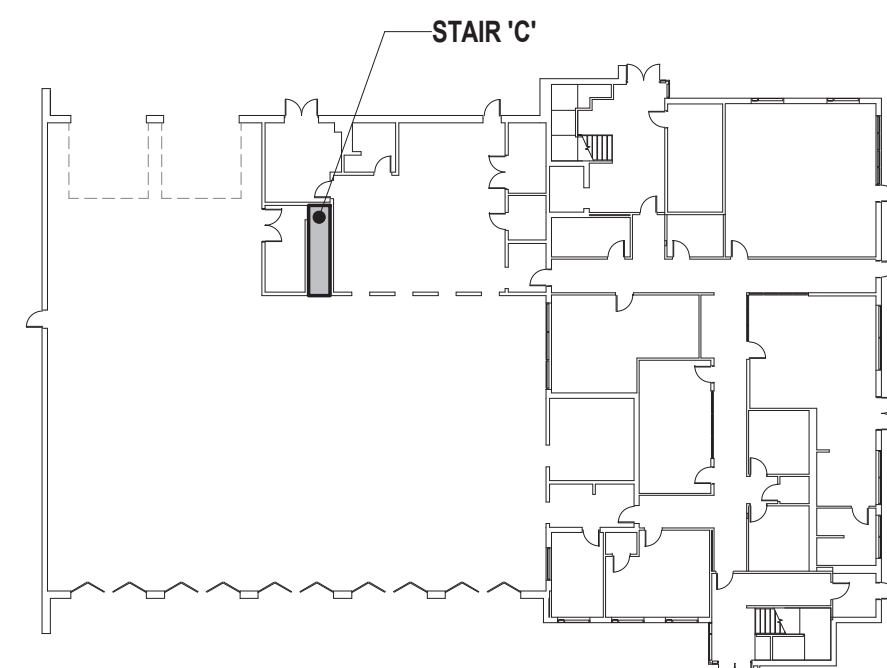

First Floor Key Plan
SCALE: NTS

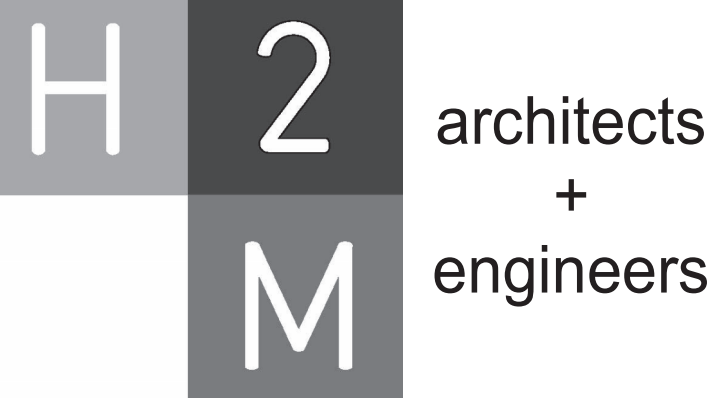

538 Broad Hollow Road, 4th Floor East
Melville, NY 11747
631.756.8000 • www.h2m.com
NY Architecture & Landscape Architecture: No Certificate Required
NY Engineering Certificate of Authorization No.: 0018178

CONSULTANTS:

MARK	DATE	DESCRIPTION



Patrick O. Stone
PATRICK O. STONE, R.A.
NY PROFESSIONAL ARCHITECT LIC. NO. 039654
10/31/2025
Exp. Date

DESIGNED BY:	DRAWN BY:	CHECKED BY:	REVIEWED BY:
DBS/RLG	ANK	DBS	POS
PROJECT No:	DATE:	SCALE:	AS SHOWN
TRFD 2302	FEBRUARY 2025		

CLIENT

**THIELLS
ROSEVILLE FIRE
DISTRICT**

**NEW 26-100 FIRE
HEADQUARTERS**

**65 W RAMAPO ROAD
GARNERVILLE, NY 10923**

CONTRACT

**CONTRACT G
GENERAL CONSTRUCTION**

STATUS

FINAL BID DOCUMENT












SHEET TITLE

**ENLARGED STAIR 'C' PLANS AND
SECTIONS**

DRAWING No.

A 402.00


C:\Users\skelley\Documents\TRFD2302_Central23_A_A\Kaled.rvt 2/25/2025 4:08:04 PM

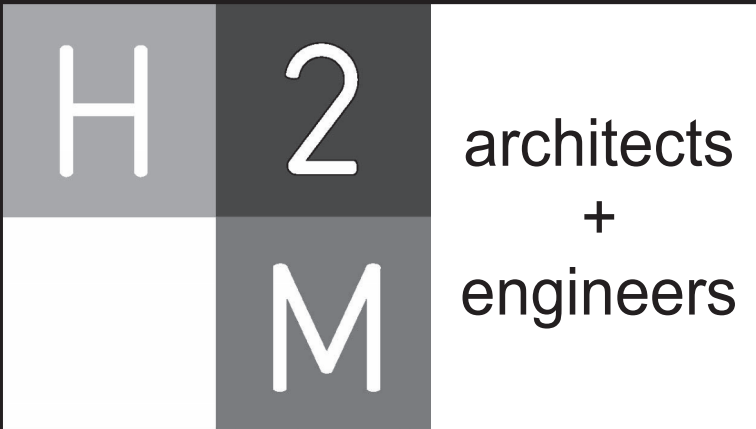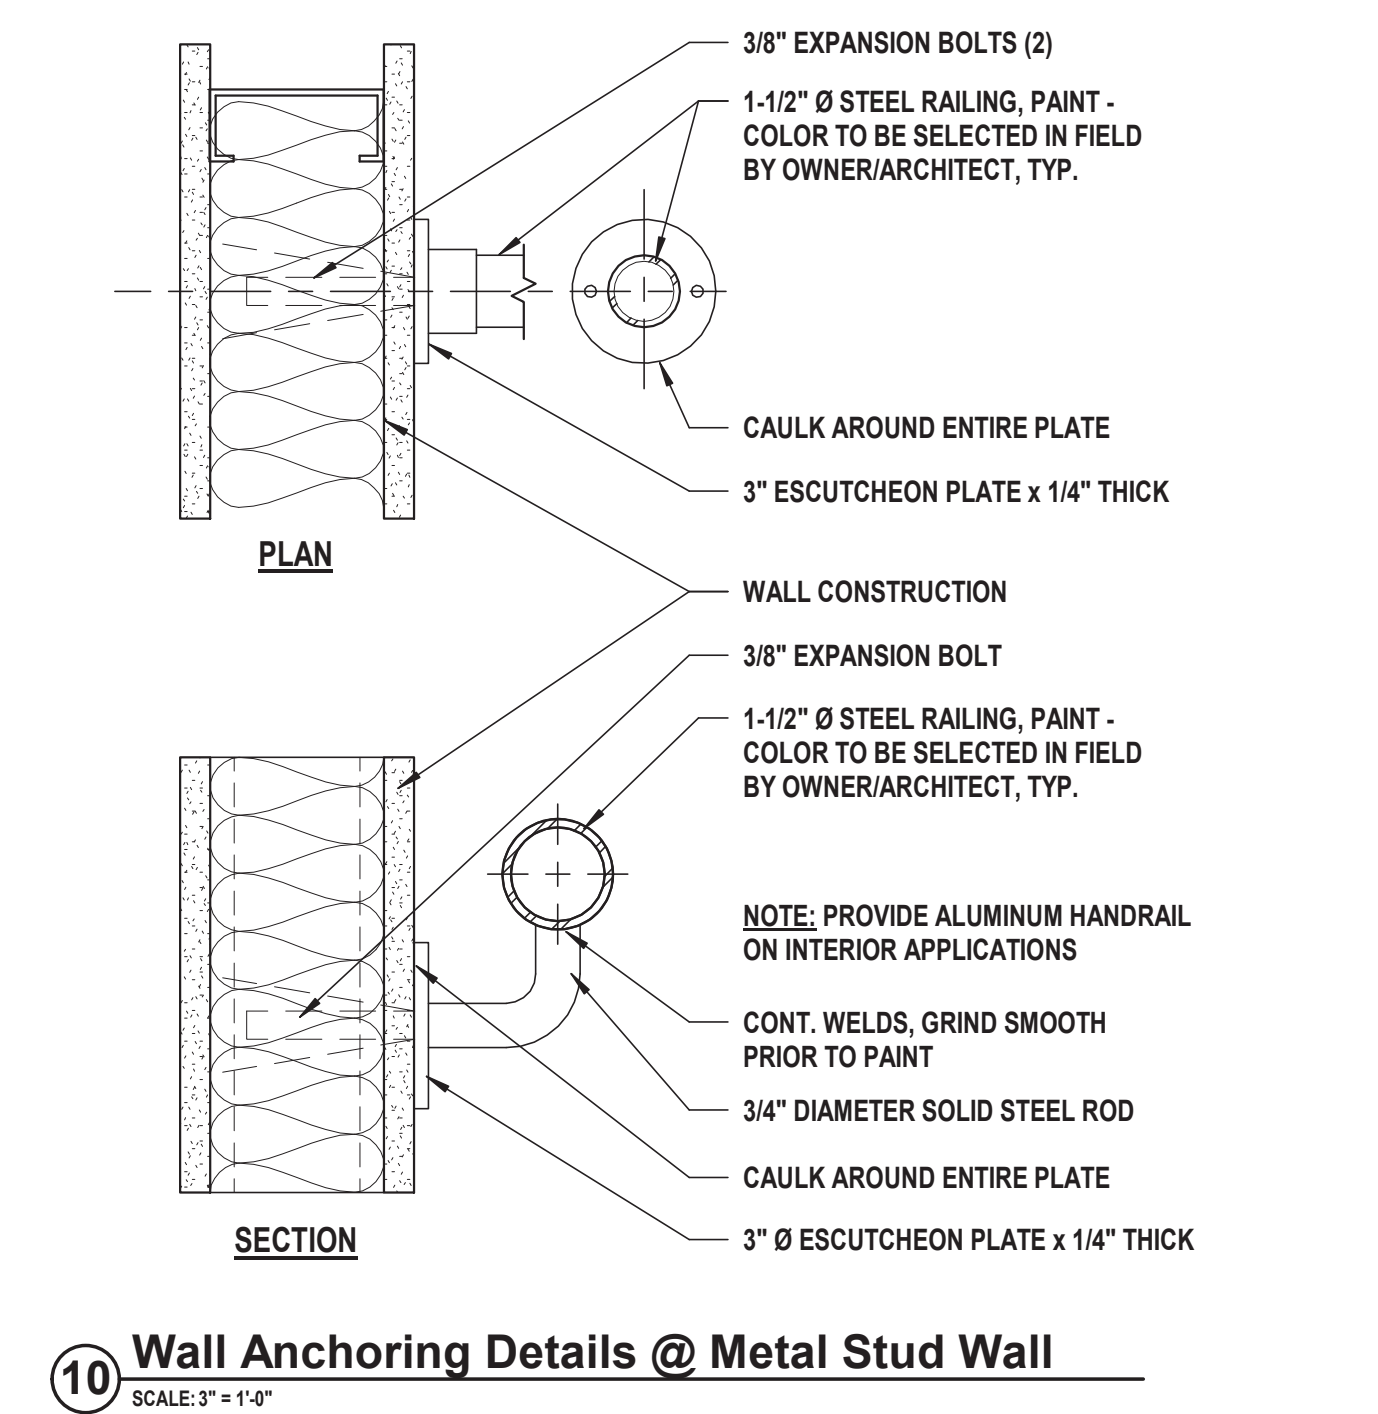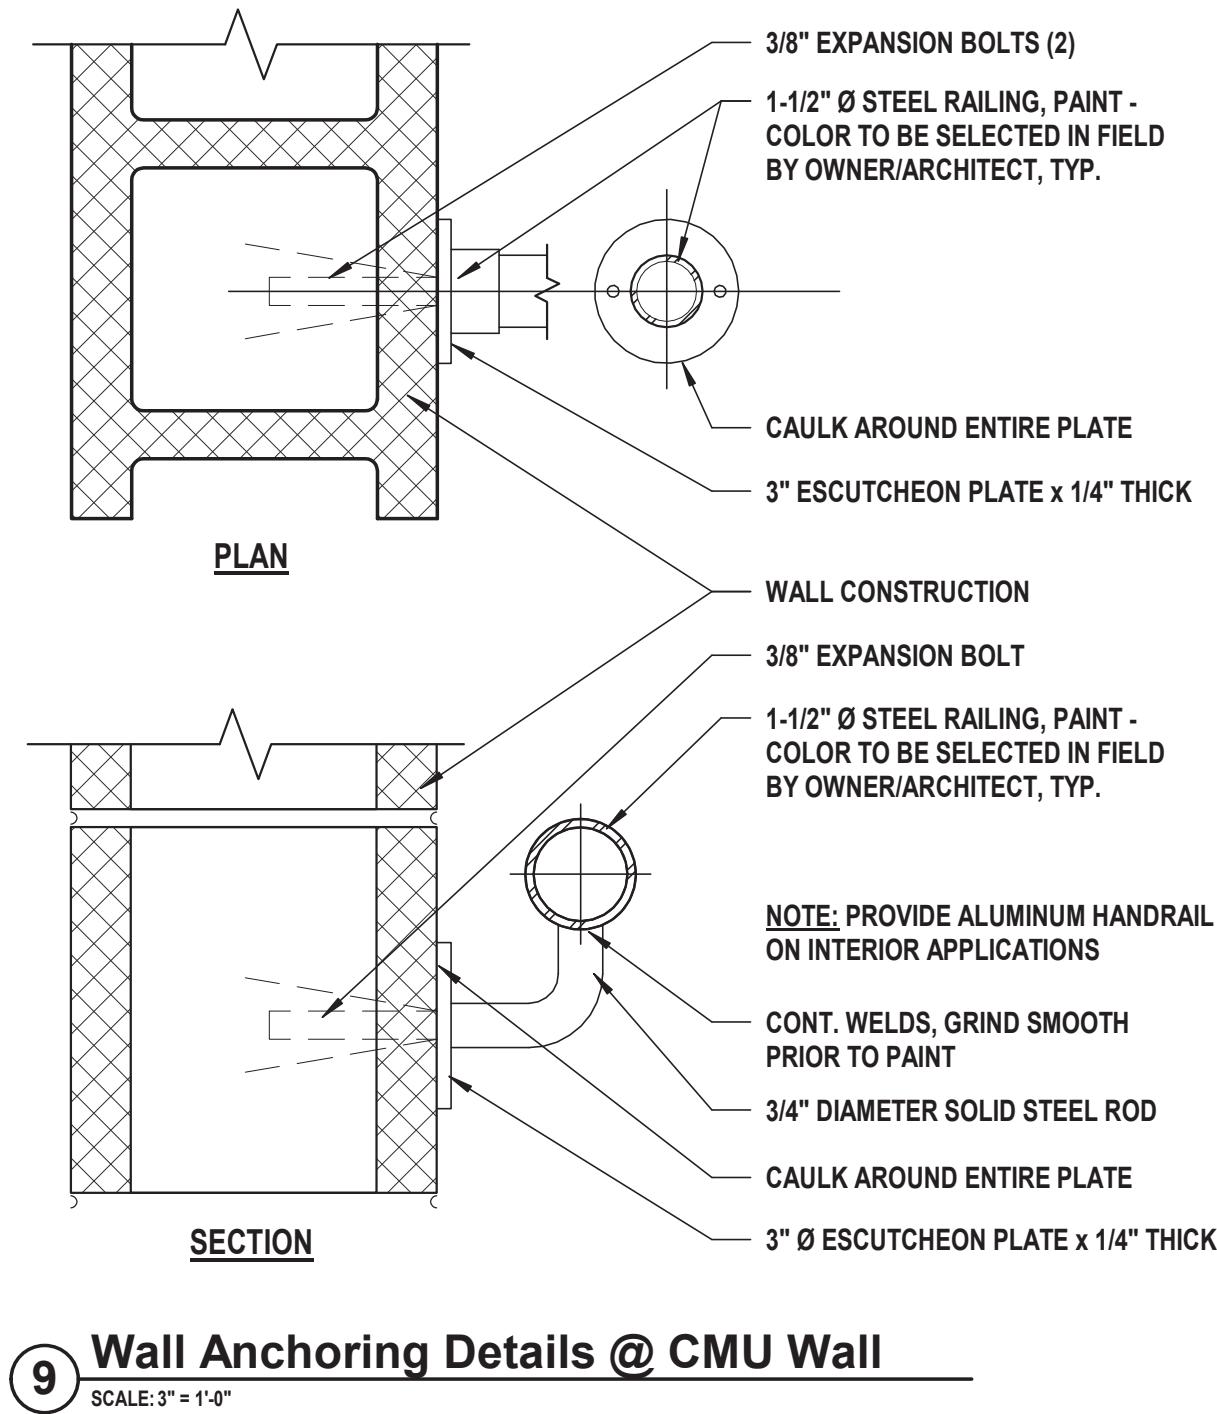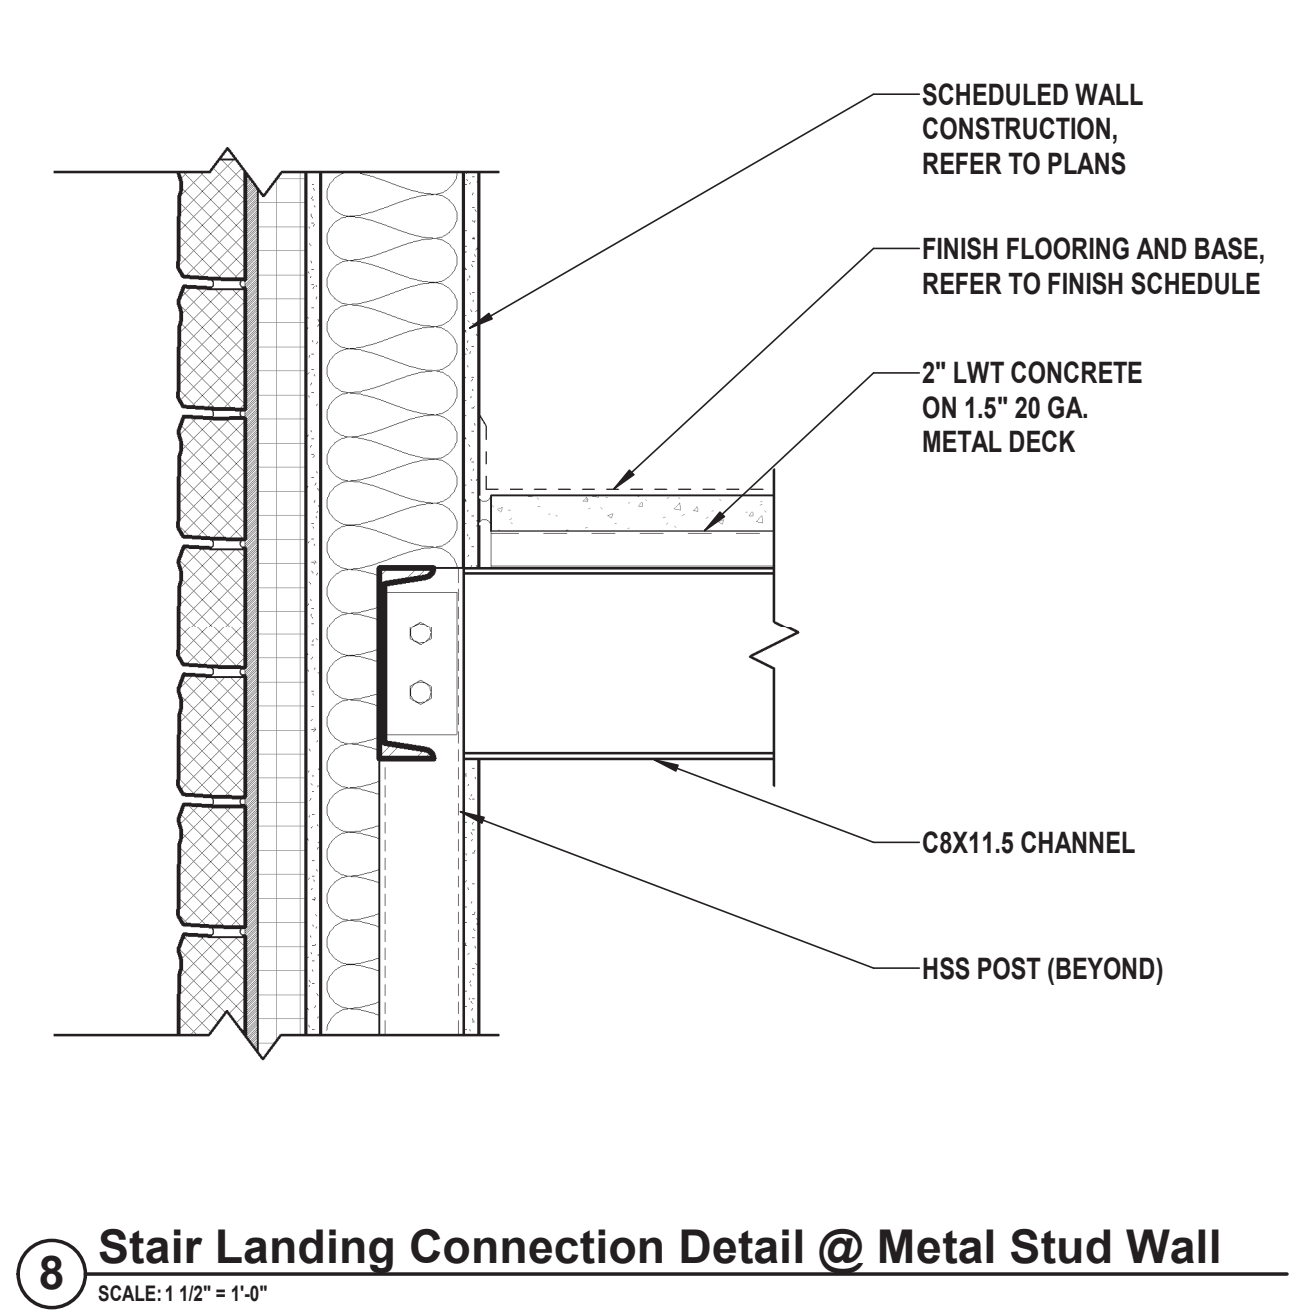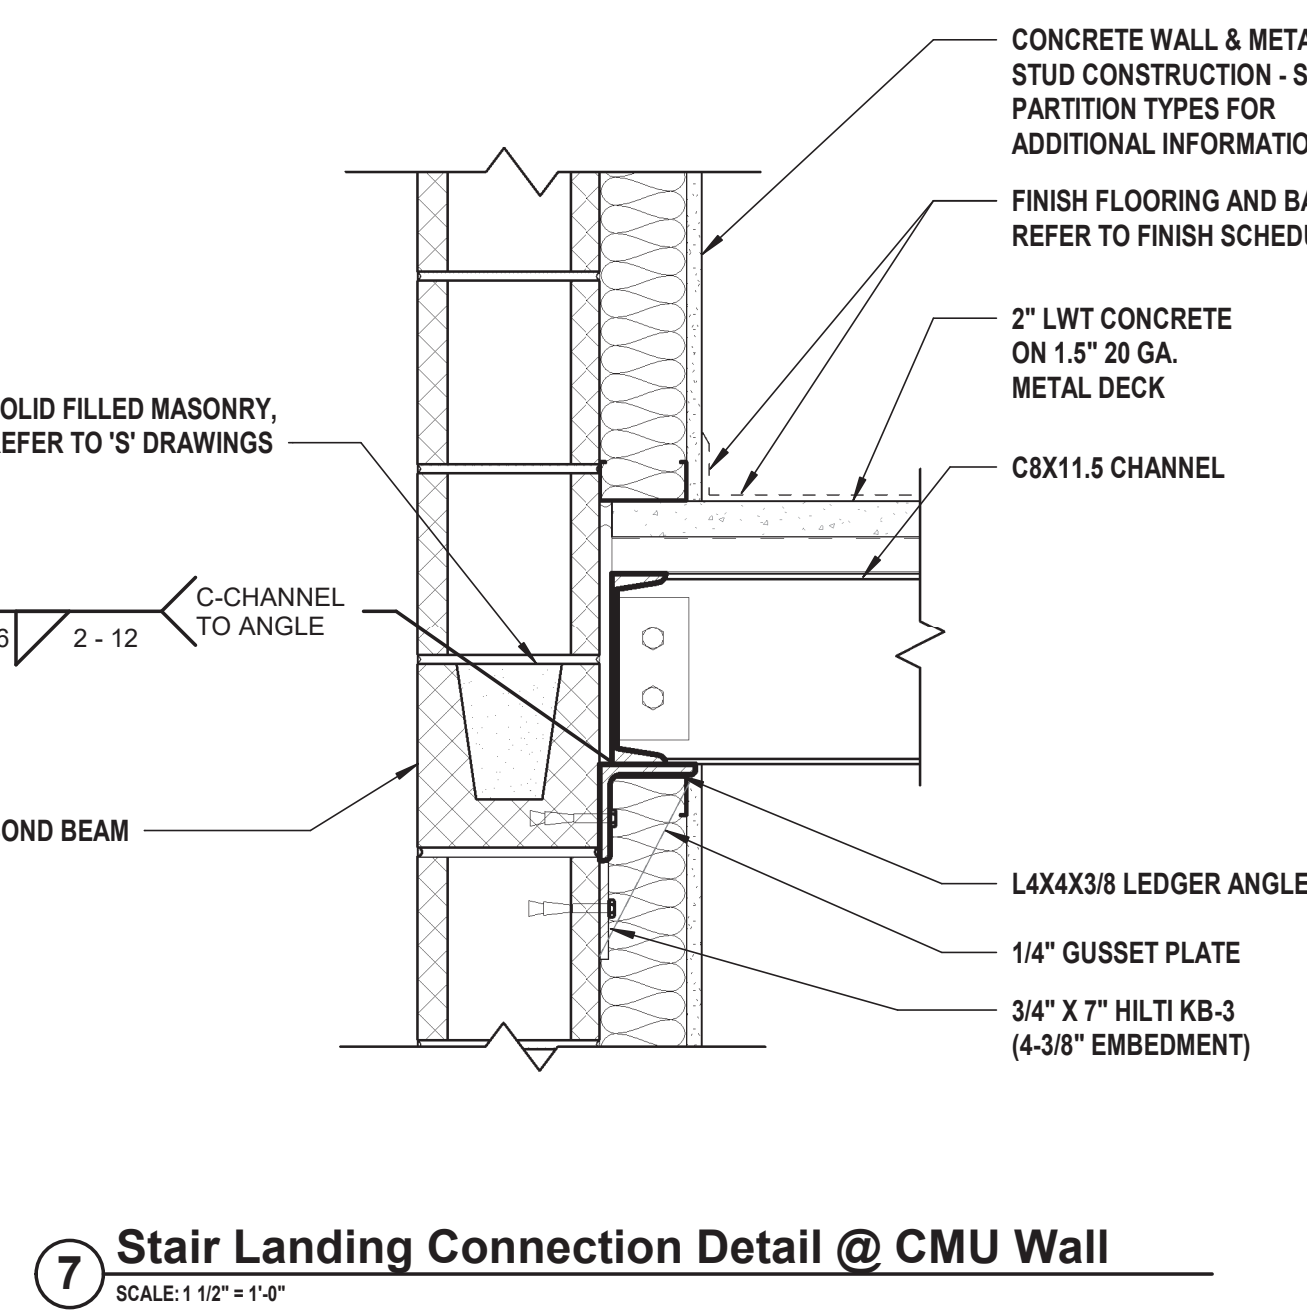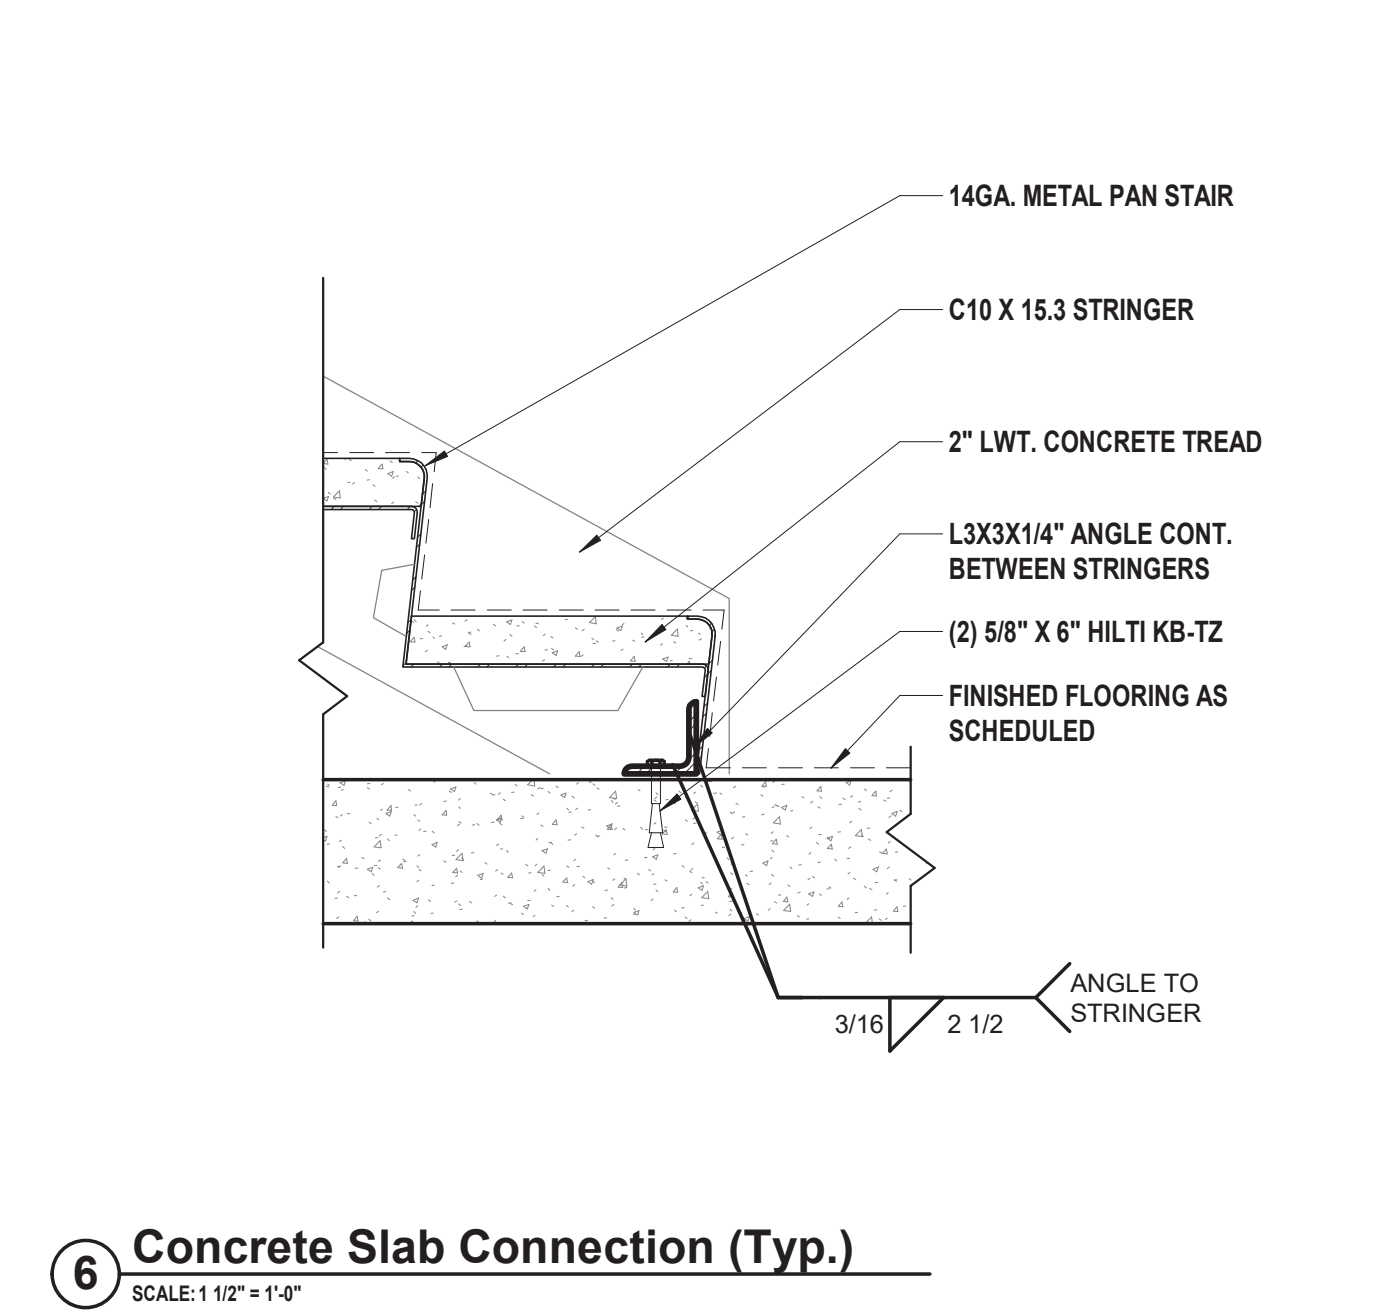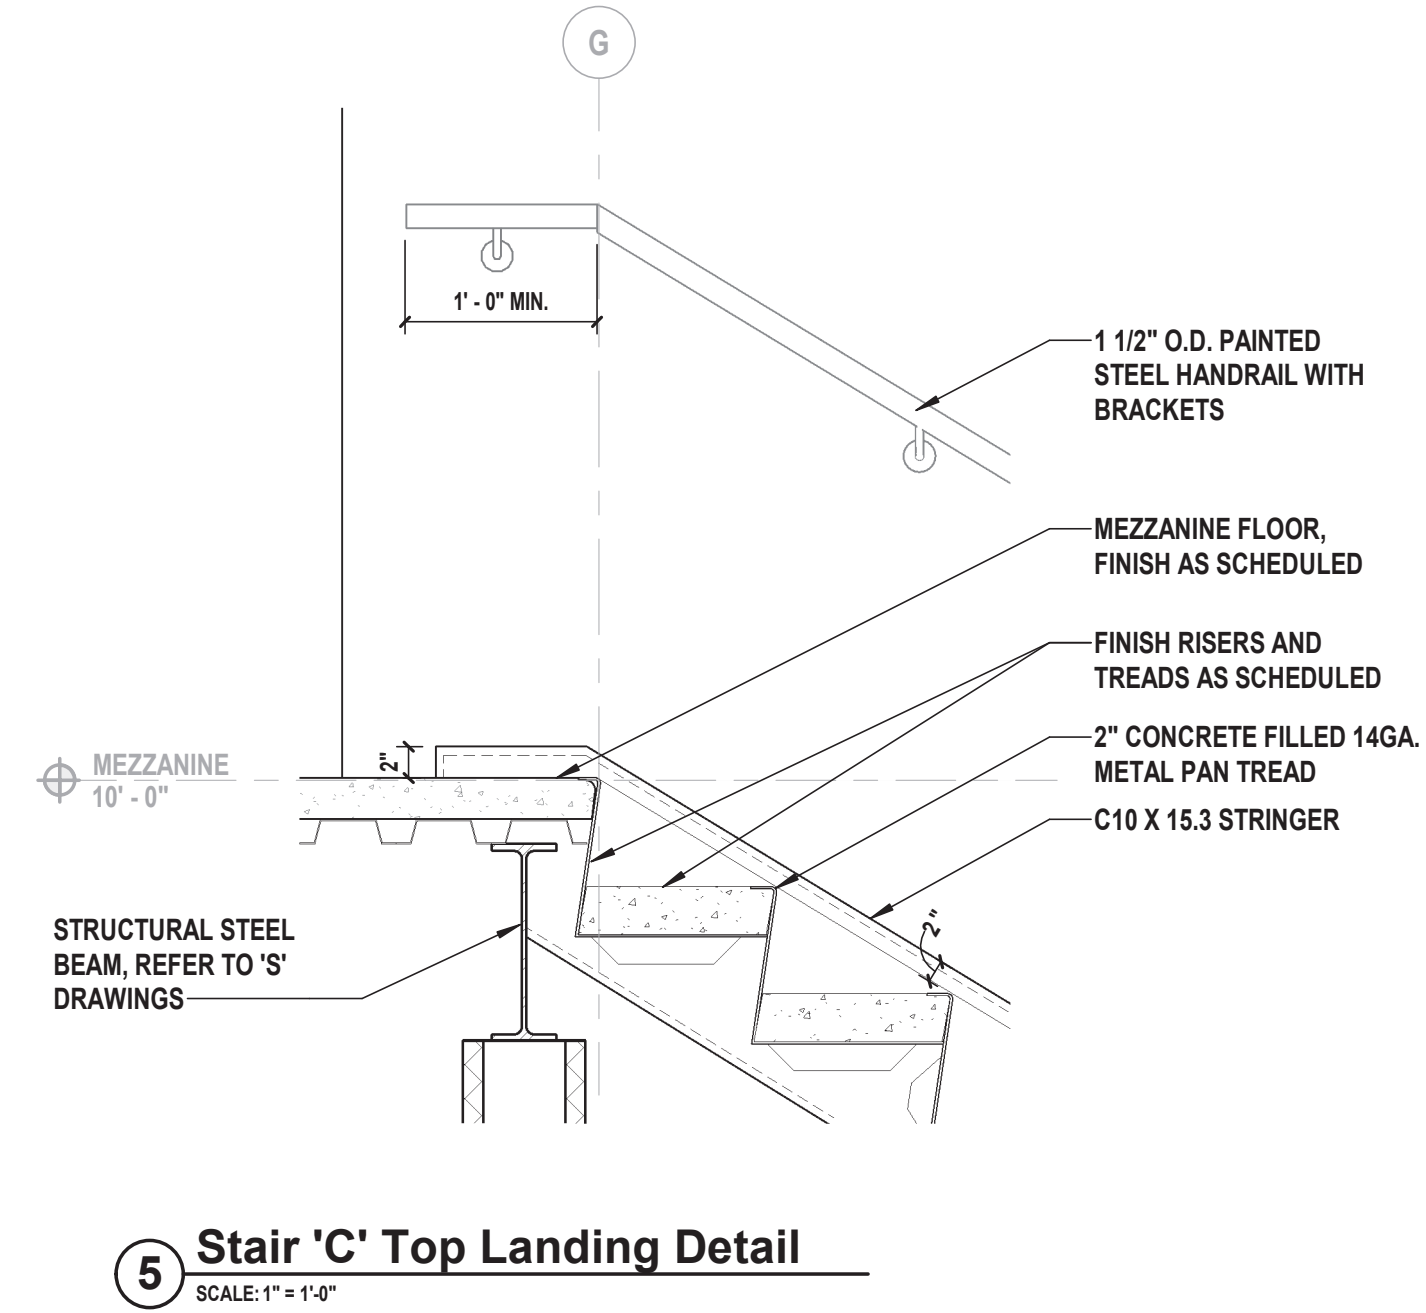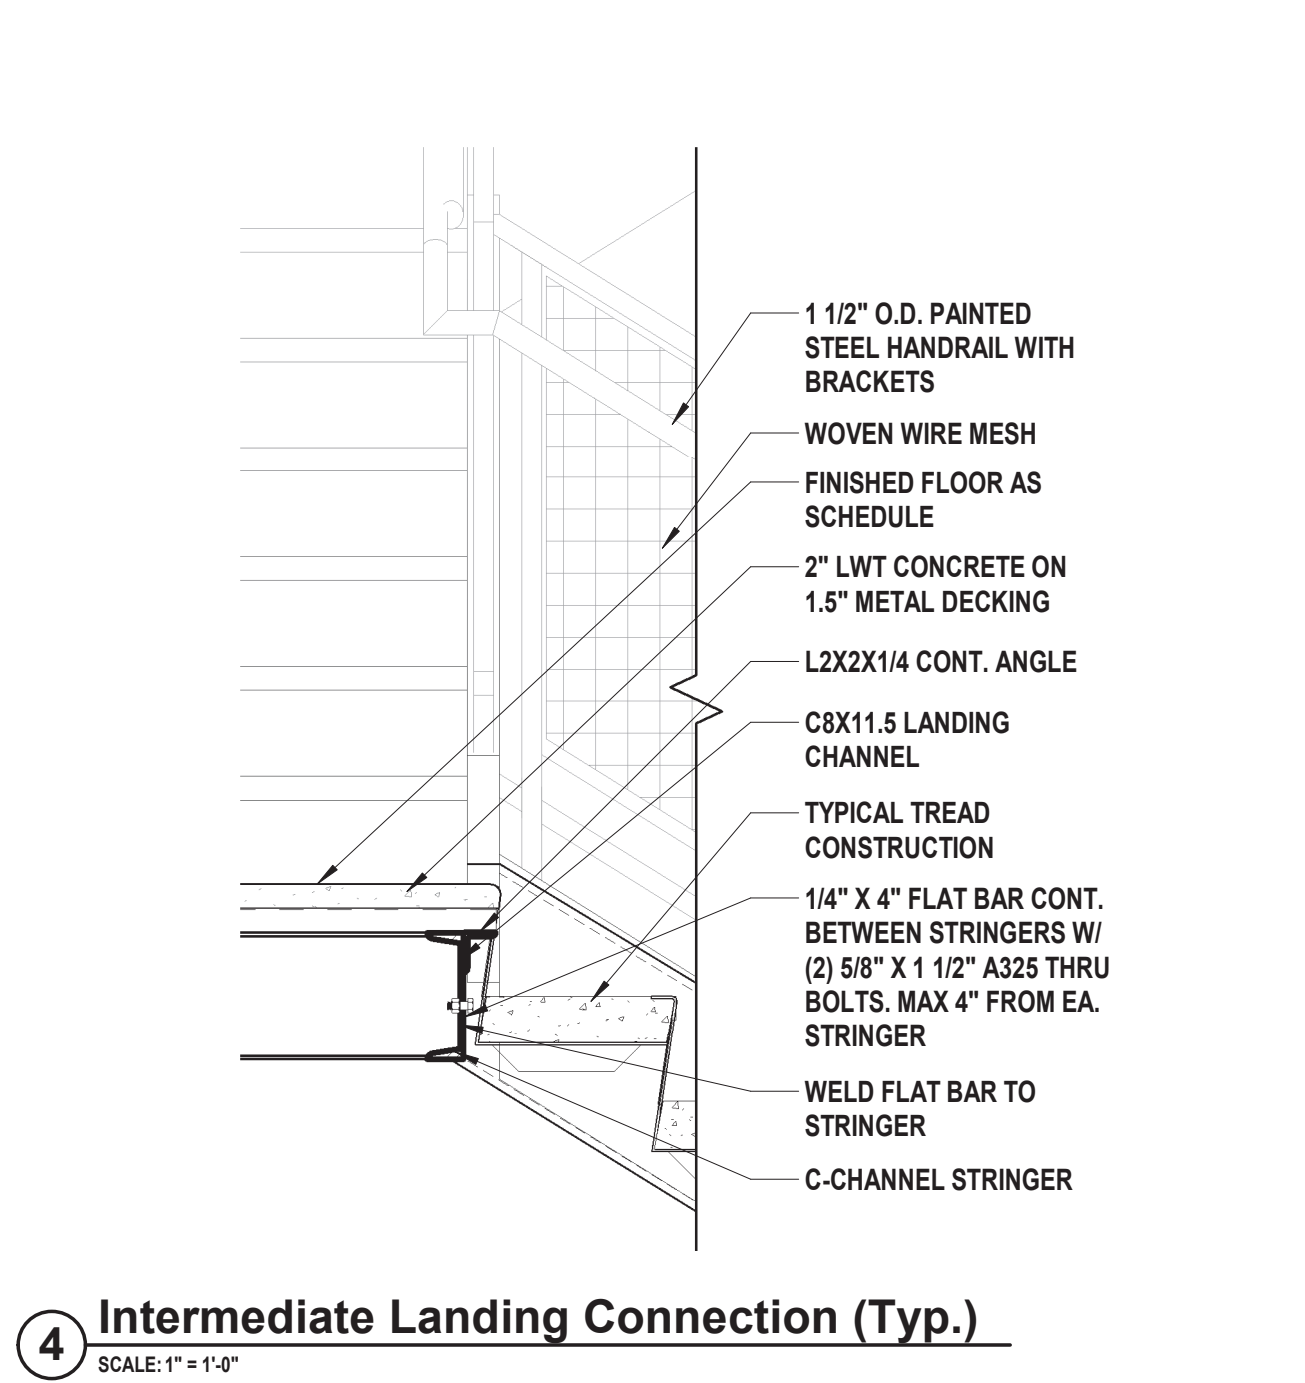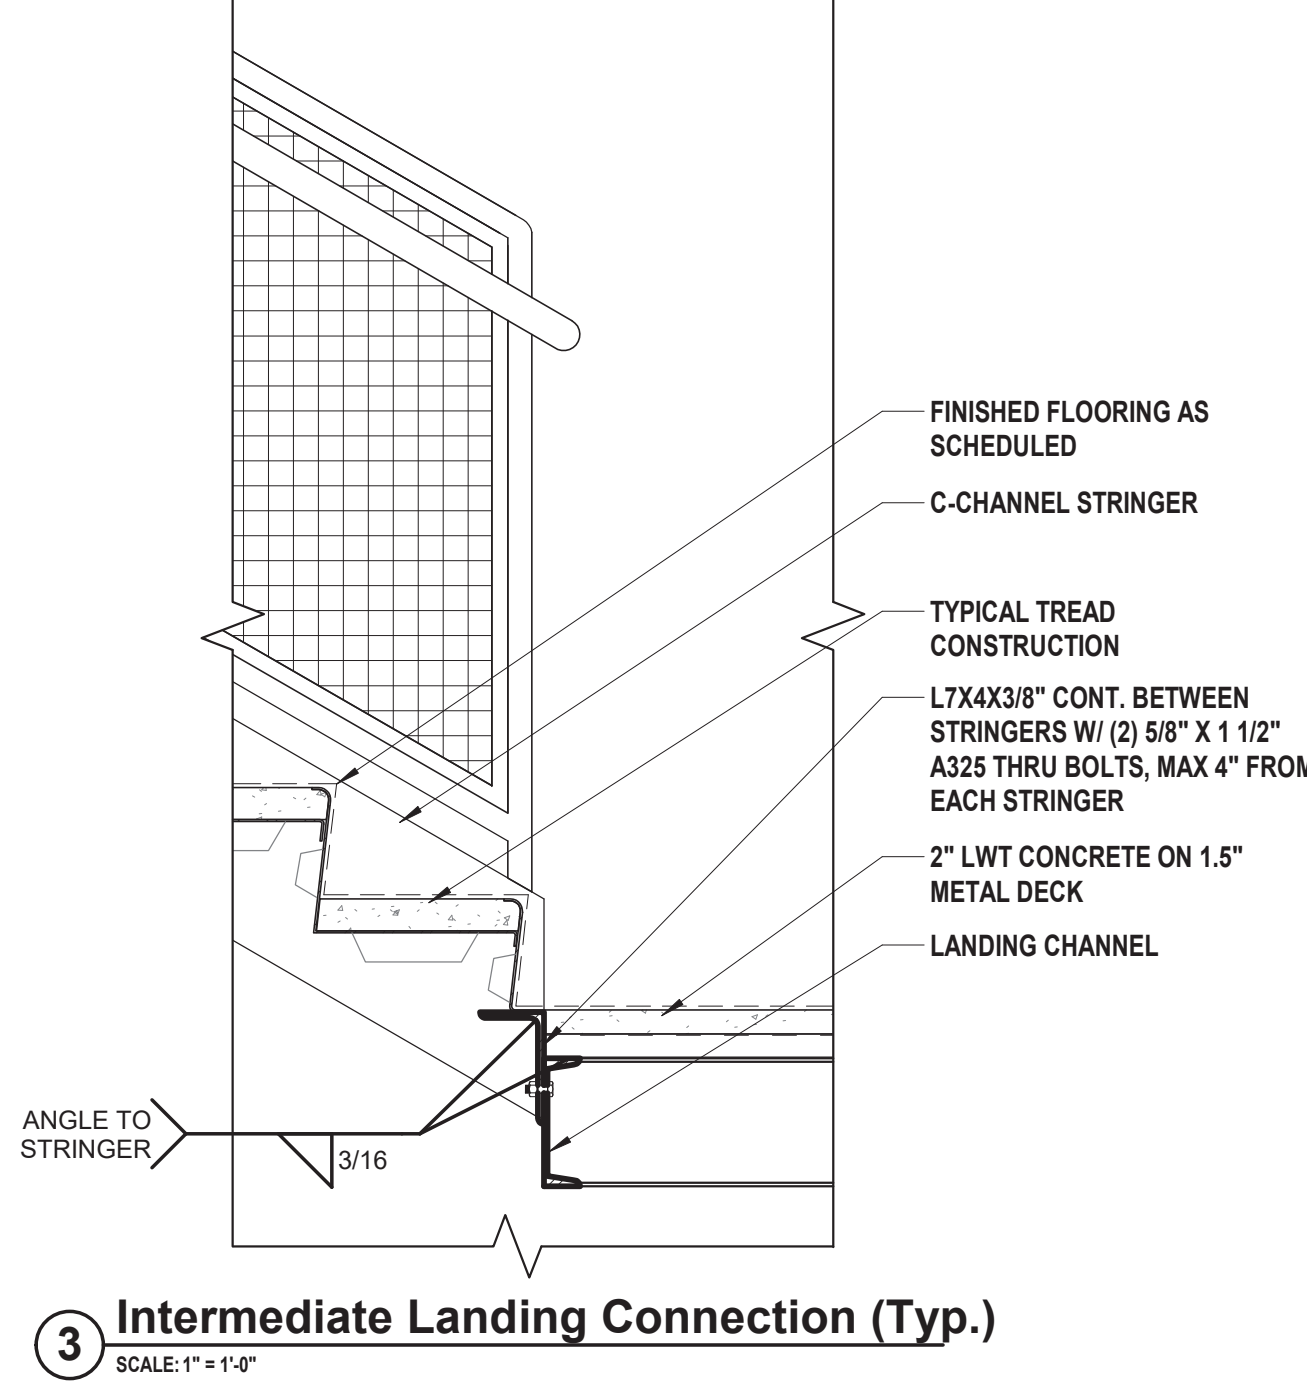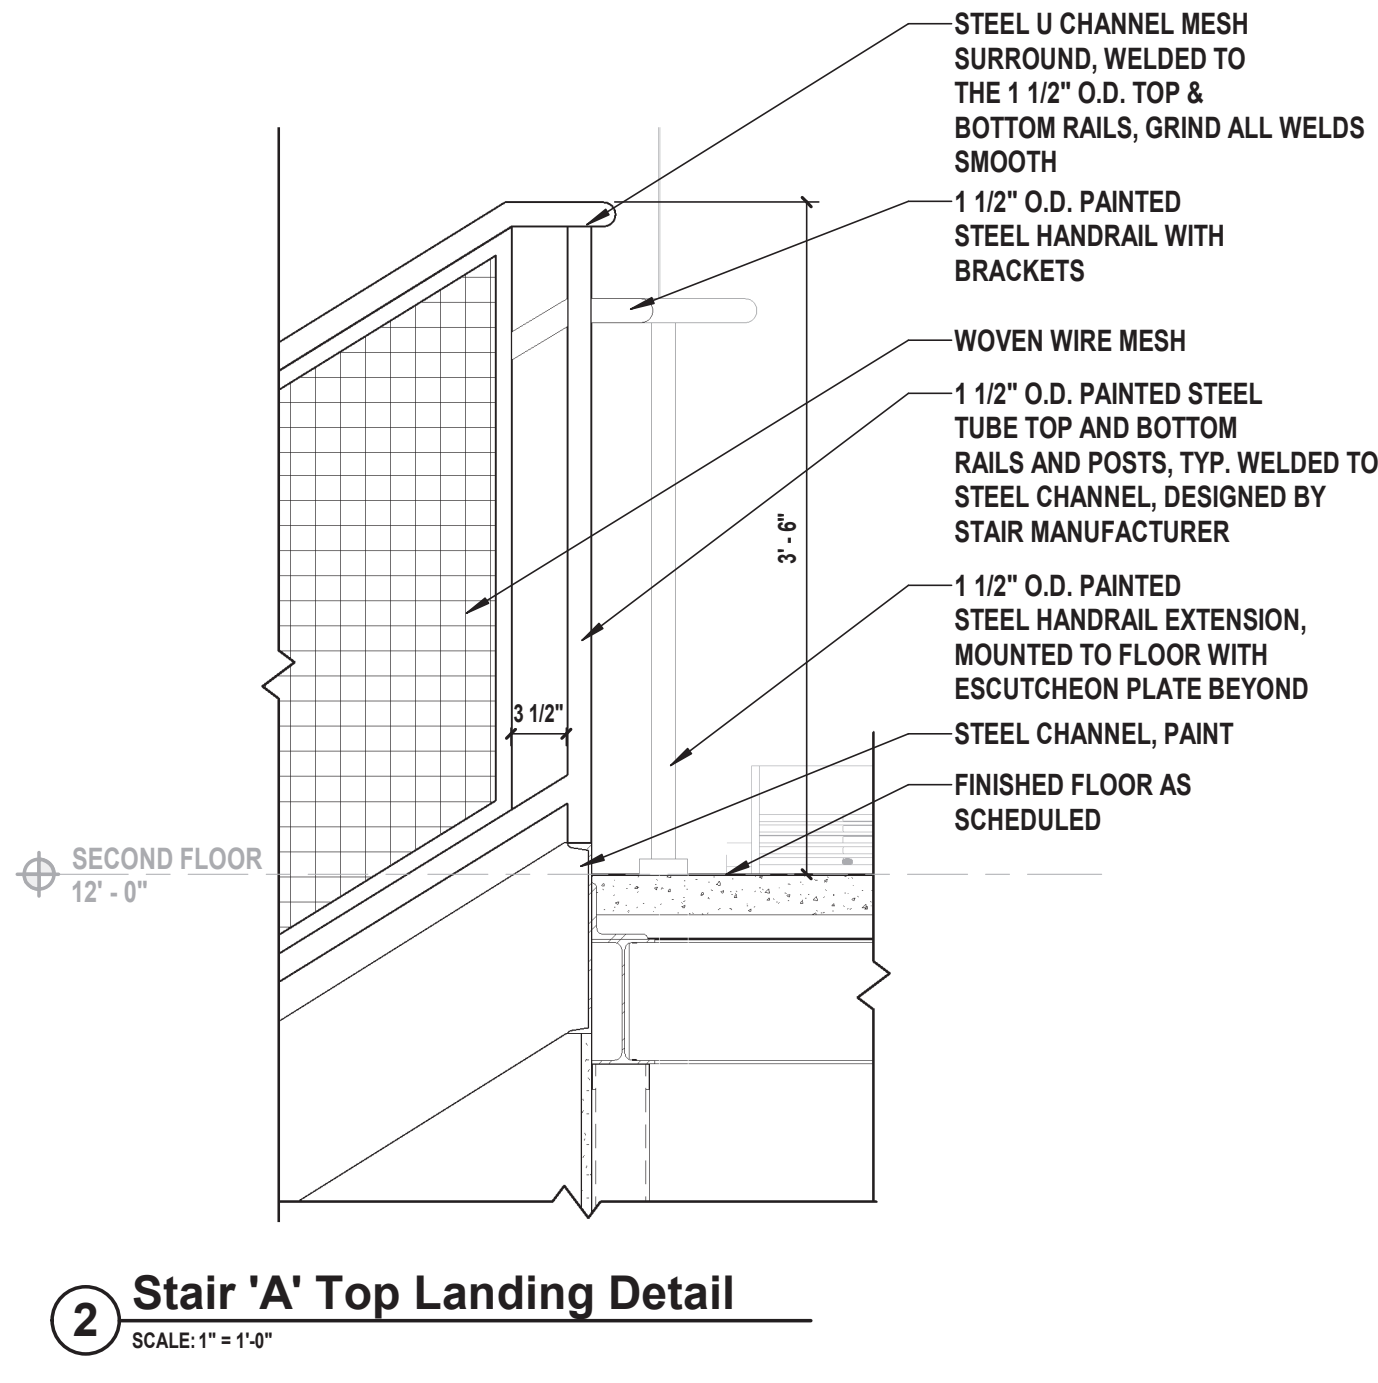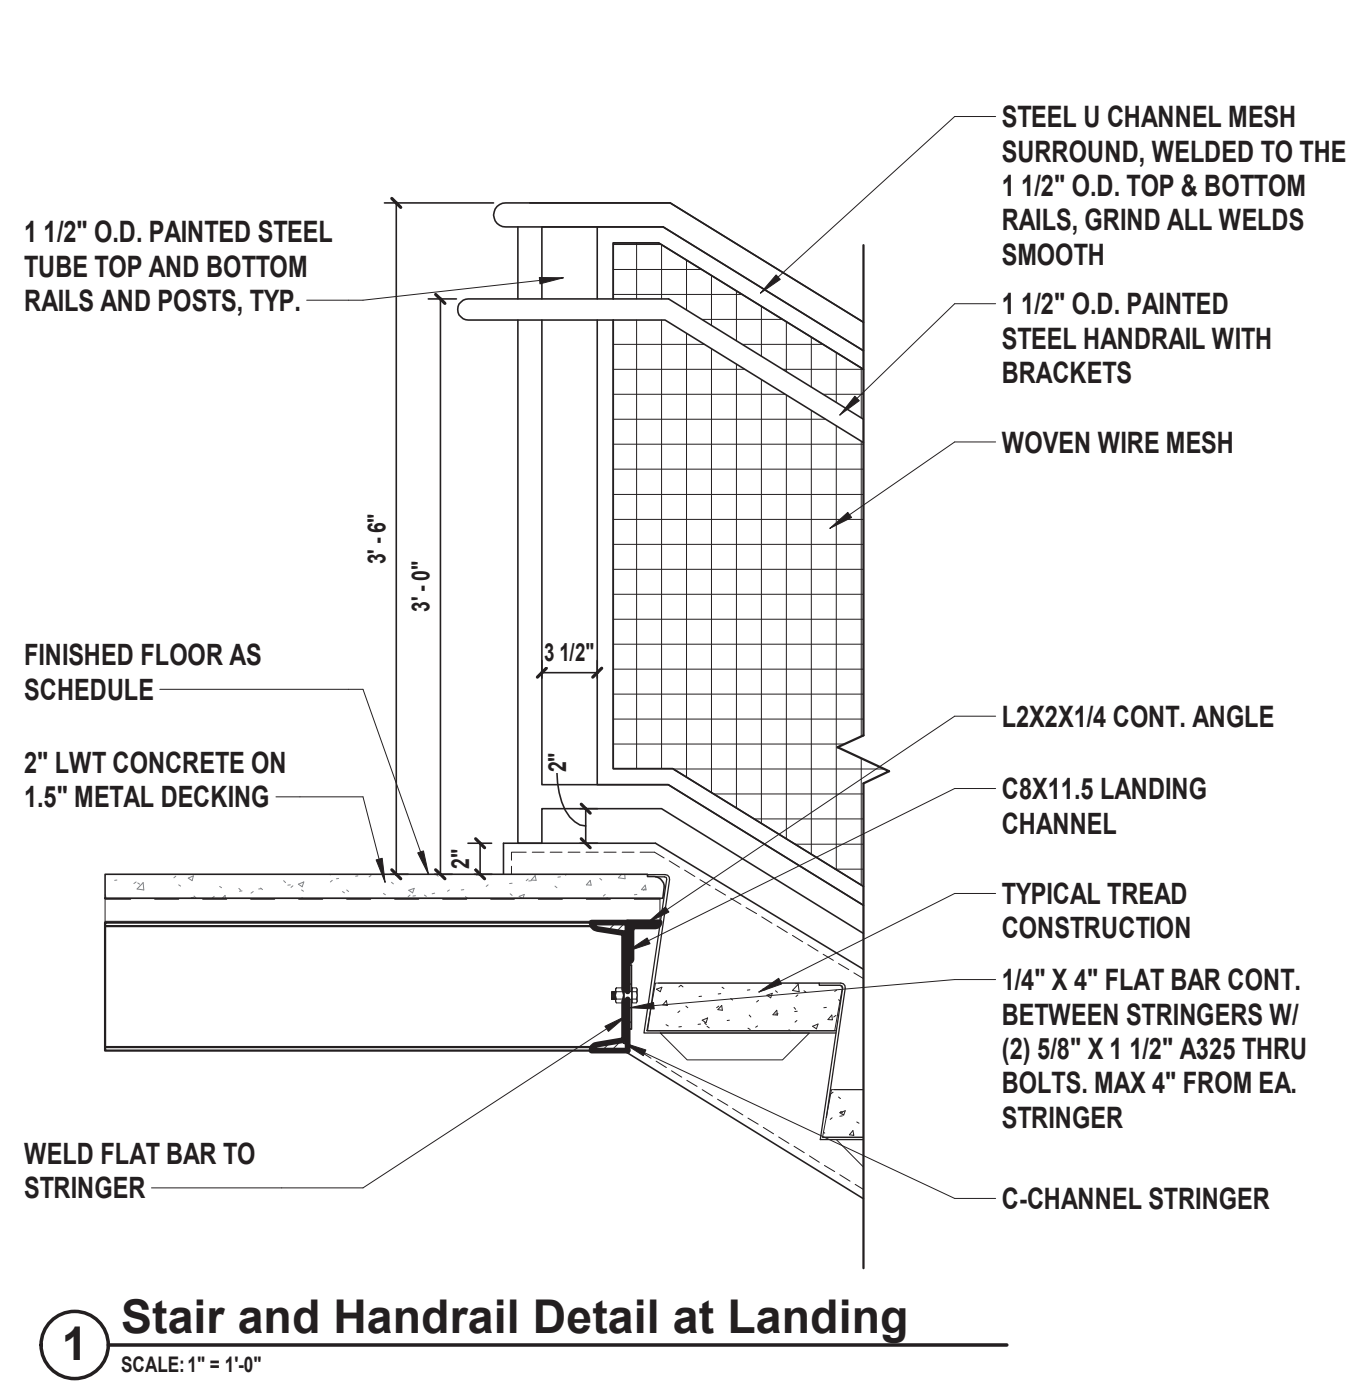

538 Broad Hollow Road, 4th Floor East
Melville, NY 11747
631.756.8000 • www.h2m.com
NY Architecture & Landscape Architecture: No Certificate Required
NY Engineering Certificate of Authorization No.: 0018178

CONSULTANTS:		

MARK	DATE	DESCRIPTION

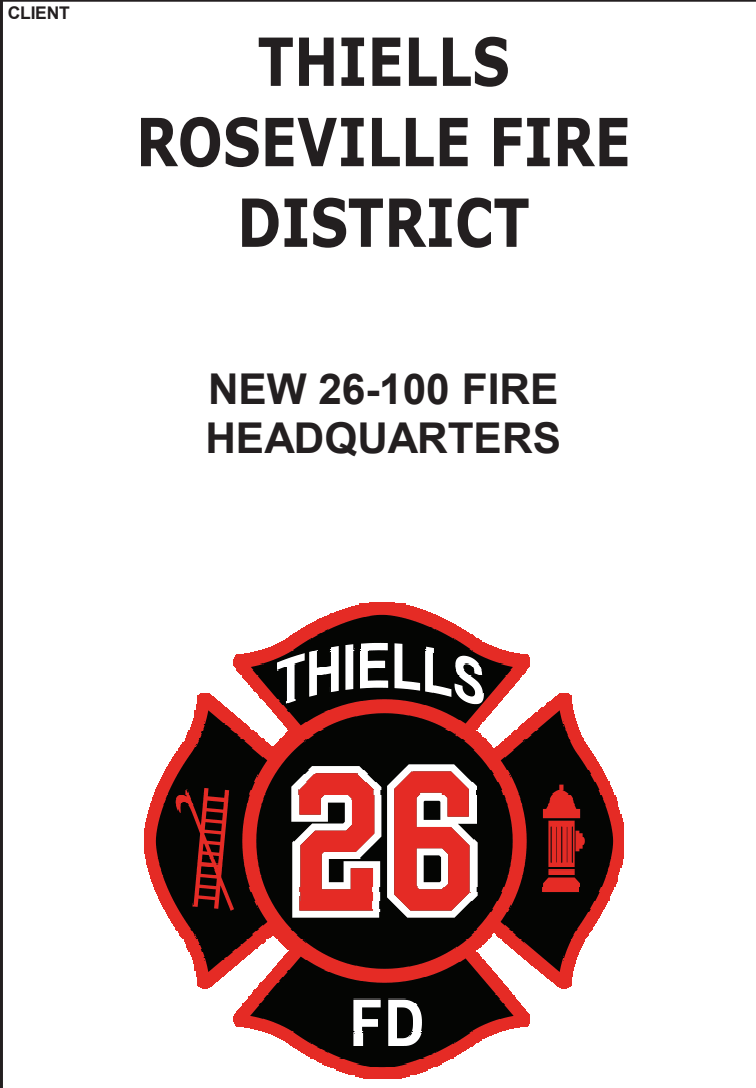

65 W RAMAPO ROAD
GARNERVILLE, NY 10923

CONTRACT
**CONTRACT G
GENERAL CONSTRUCTION**

STATUS
FINAL BID DOCUMENT

SHEET TITLE
STAIR AND RAILING DETAILS

DRAWING No.
A 403.00

CONSULTANTS:		

MARK	DATE	DESCRIPTION

REGISTERED ARCHITECT
PATRICK O. STONE
STATE OF NEW YORK
029654

Patrick O. Stone
PATRICK O. STONE, R.A.
NY PROFESSIONAL ARCHITECT LIC. NO. 029654
10/31/2025
Exp. Date

DESIGNED BY: DBS/RLG
PROJECT No: TRFD 2302

DRAWN BY: ANK
DATE: FEBRUARY 2025

CHECKED BY: DBS
SCALE: AS SHOWN

REVIEWED BY: POS

THIELLS
ROSEVILLE FIRE
DISTRICT

NEW 26-100 FIRE
HEADQUARTERS

THIELLS
26
FD

65 W RAMAPO ROAD
GARNERVILLE, NY 10923

CONTRACT
CONTRACT G
GENERAL CONSTRUCTION

STATUS
FINAL BID DOCUMENT

SHEET TITLE
ENLARGED ELEVATOR PLAN,
SECTION, DETAILS & NOTES

DRAWING No.
A 404.00

- GENERAL ELEVATOR REQUIREMENT NOTES
1. PROVIDE PLUMB, PROPERLY FRAMED AND ENCLOSED LEGAL HOISTWAY INCLUDING VENTING (AS REQUIRED BY THE GOVERNING CODES) AND SAFETY BEAM, AS SHOWN.

2. PROVIDE ADEQUATE SUPPORT FOR JACK, GUIDE RAIL BRACKETS (NOT TO EXCEED THE VERTICAL SPACING INDICATED), AND BUFFERS. SEPARATOR BEAMS TO BE PROVIDED WHERE REQUIRED BY MANUFACTURER.

3. ADEQUATE PROVISIONS FOR GUARDING AND PROTECTING THE HOISTWAY DURING CONSTRUCTION ARE TO BE ERECTED, MAINTAINED, AND REMOVED BY CONTRACTOR.

4. PROVIDE ALL CUTTING OR PATCHING AS REQUIRED TO ACCOMMODATE ELEVATOR INSTALLATION, INCLUDING CUTOUTS REQUIRED FOR OIL AND POWER LINE RUNS (COORDINATE CUTOUT LOCATIONS WITH ELEVATOR MANUFACTURER).

5. HOISTWAY WALLS ARE TO BE CONSTRUCTED IN ACCORDANCE WITH THE REQUIRED FIRE RATING (INCLUDING LOCATIONS WHERE PENETRATED BY ELEVATOR FIXTURE BOXES), AND TO INCLUDE ADEQUATE FASTENINGS TO HOISTWAY ASSEMBLIES. COORDINATE LOCATION AND INSTALLATION OF HORIZONTAL SUPPORTS ABOVE THE CLEAR OPENINGS AT EACH LANDING AS REQUIRED TO SUPPORT THE DOOR FRAME ASSEMBLY. THE ENTRANCE WALL(S) MUST NOT BE COMPLETELY CONSTRUCTED UNTIL THE FRAMES AND SILLS ARE SET.

6. COORDINATE WITH ELEVATOR MANUFACTURER ALL ROUGH DOOR OPENINGS AND POCKETS IN WALL CONSTRUCTION (AS REQUIRED TO INSTALL ENTRANCE FRAMES, HALL FIXTURES, ETC.).

7. ELEVATOR CAB FLOORING MUST NOT EXCEED A THICKNESS OF 5/16". MODIFY FLOORING AS REQUIRED TO ACCOMMODATE INSTALLATION.

8. PROVIDE A FIXED VERTICAL STEEL LADDER TO PIT EXTENDING 4'-0" ABOVE THE SILL OF THE BOTTOM ENTRANCE AS LOCATED IN THE PLAN VIEW. LADDER WIDTH AND PROJECTION FROM WALL PER LOCAL CODE, AND ELEVATOR MANUFACTURER'S REQUIREMENTS.

9. DRY PIT TO BE REINFORCED TO SUSTAIN VERTICAL FORCES AS DETERMINED BY ELEVATOR MANUFACTURER. THE ACCUMULATION OF WATER MUST BE PREVENTED.

10. PIT FLOOR BENEATH CYLINDERS AND BUFFER TO BE FLAT AND LEVEL WITHIN 1/8" FULL WIDTH HOISTWAY. SLOPE REMAINING PIT FLOOR TO SUMP AREA FOR REMOVAL OF FLUID IN PIT. FINAL LOCATION AND SIZE OF SUMP TO BE COORDINATED WITH MANUFACTURER TO AVOID ELEVATOR COMPONENTS AND ACCESS AREA.

11. PROVIDE A THREE PHASE POWER SYSTEM, 120V 15 AMP CIRCUIT, FIRE ALARM AND OUTSIDE DEDICATED TELEPHONE LINE ROUTED TO THE TOP OF THE CONTROLLER AT THE CONTROLLER LANDING LEVEL.

12. IN THE PIT, PROVIDE A SEPARATE BRANCH CIRCUIT FOR CONVENIENCE G.F.C.I. OUTLETS AND LIGHT FIXTURE WITH LIGHT SWITCH (ADJACENT TO THE PIT LADDER AS INDICATED).

13. ALL 125 VOLT, 15 OR 20 AMP, SINGLE PHASE DUPLEX RECEPTACLES INSTALLED IN PITS OR MACHINERY SPACES, SHALL BE OF THE GROUND-FAULT- CIRCUIT-INTERRUPTER TYPE. SEE 'E' DRAWINGS AND SPECIFICATIONS FOR ADDITIONAL INFORMATION.

14. PROVIDE ELECTRIC POWER FOR TOOLS, LIGHT, HOIST, ETC., DURING ERECTION AS WELL AS ELECTRIC CURRENT FOR STARTING AND ADJUSTING THE ELEVATOR. SEE 'E' DRAWINGS AND SPECIFICATIONS FOR ADDITIONAL INFORMATION.

15. PROVIDE ONE (1) DEDICATED OUTSIDE TELEPHONE LINE ROUTED TO THE TOP OF THE CONTROLLER AT THE CONTROLLER LANDING LEVEL. SEE 'E' DRAWINGS AND SPECIFICATIONS FOR ADDITIONAL INFORMATION.

16. PROVIDE ALL NECESSARY CONDUIT AND WIRING FROM HOISTWAY TO ELEVATOR MONITORING DEVICES (FOR SECURITY, LIFE SAFETY, AND/OR FIRE REQUIREMENTS), AS APPLICABLE. SEE 'E' DRAWINGS AND SPECIFICATIONS FOR ADDITIONAL INFORMATION.

17. PROVIDE SMOKE DETECTORS, AS REQUIRED BY NYS BUILDING CODE APPENDIX K, SECTION 2.27.3.2.1. SEE 'F'A' DRAWINGS.

18. ELEVATOR MANUFACTURE, CONSTRUCTION, FUNCTIONALITY AND IDENTIFICATION SHALL BE AS PER ASME A17.1-2016.

PIT/OVERHEAD REQUIREMENTS

SPEED	PIT DEPTH	MAXIMUM TOTAL RISE
150 F.P.M	5'-0"	12'-0"






FLOOR HEIGHT

FLOOR	FIRST	0'-0"
	SECOND	12'-0"
TOTAL RISE		12'-0"

- NOTES:
1. HOISTWAY SIZE MUST BE PLUMB WITHIN 1" AND MUST NOT BE LESS THAN FIGURES SHOWN.


2. SUMP OR DRAIN LOCATION IN PIT TO BE COORDINATED WITH MANUFACTURER TO AVOID ELEVATOR COMPONENTS AND ACCESS AREA.

3. HOISTWAY FASCIA IS NOT SELF-SUPPORTING FOR LONG, CONTINUOUS RUNS VOID OF ENTRANCES. ADEQUATE SUPPORT FOR THE FASCIA MUST BE PROVIDED.

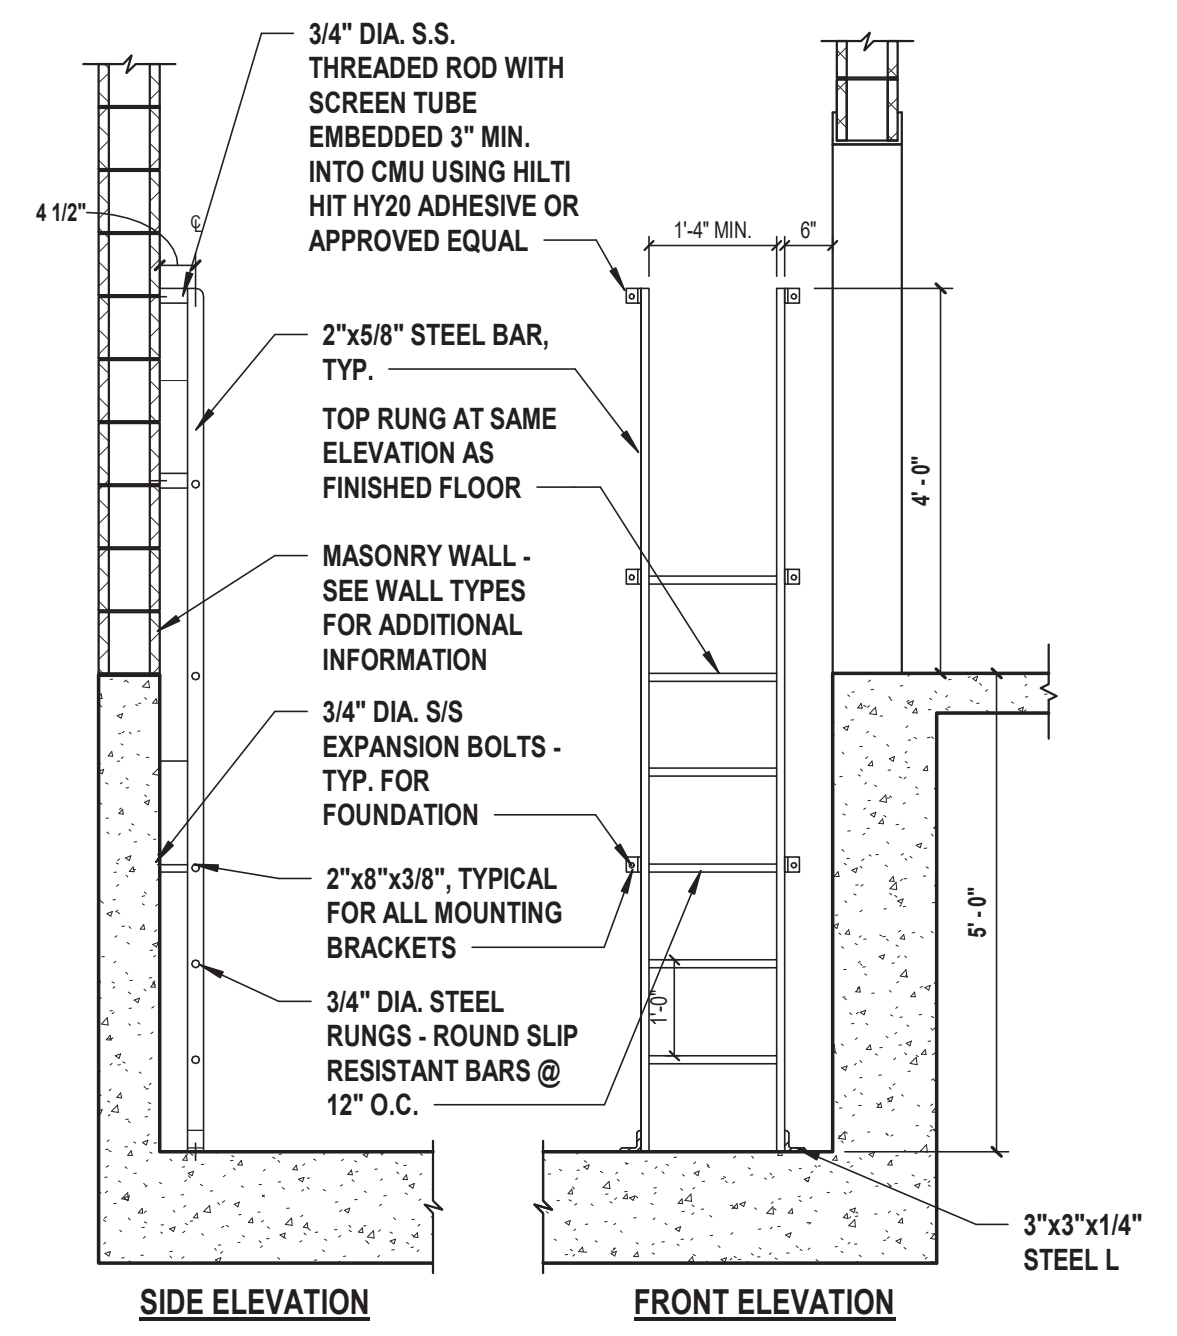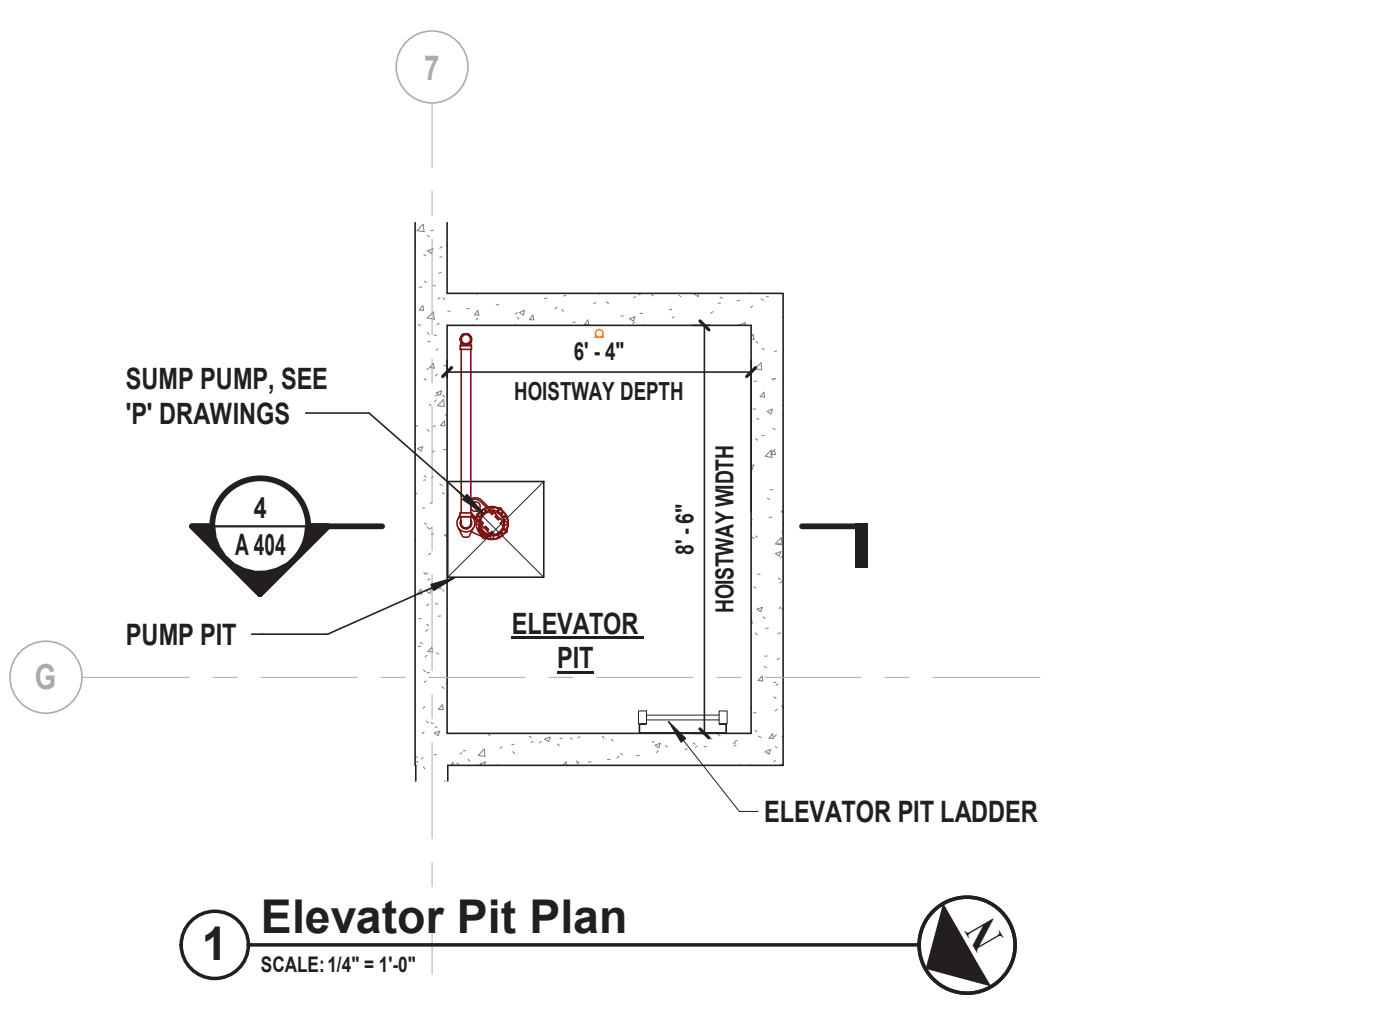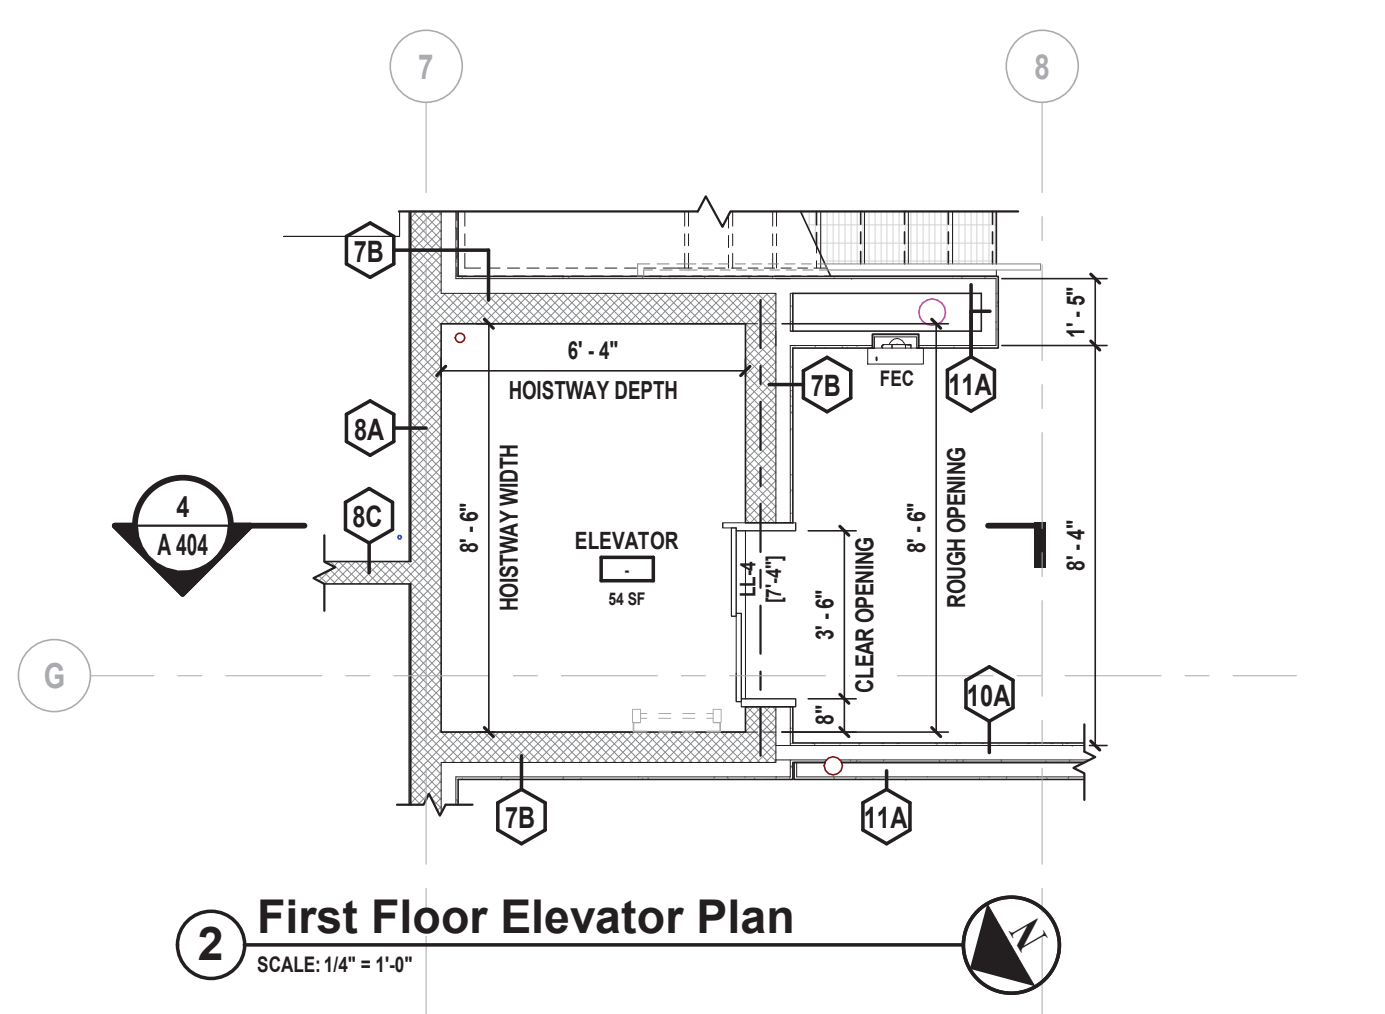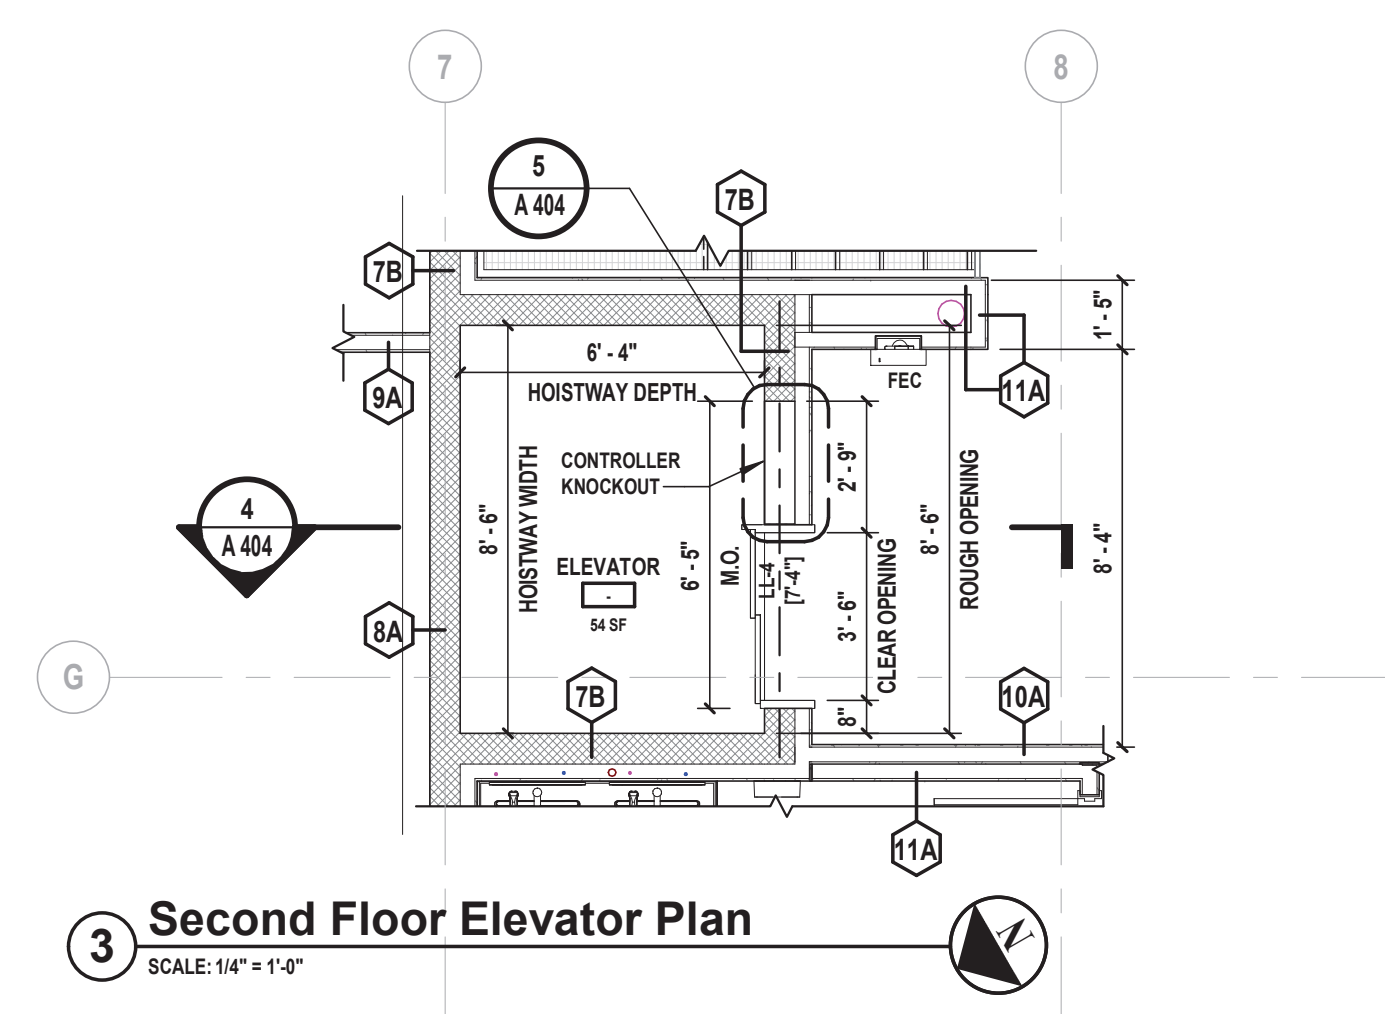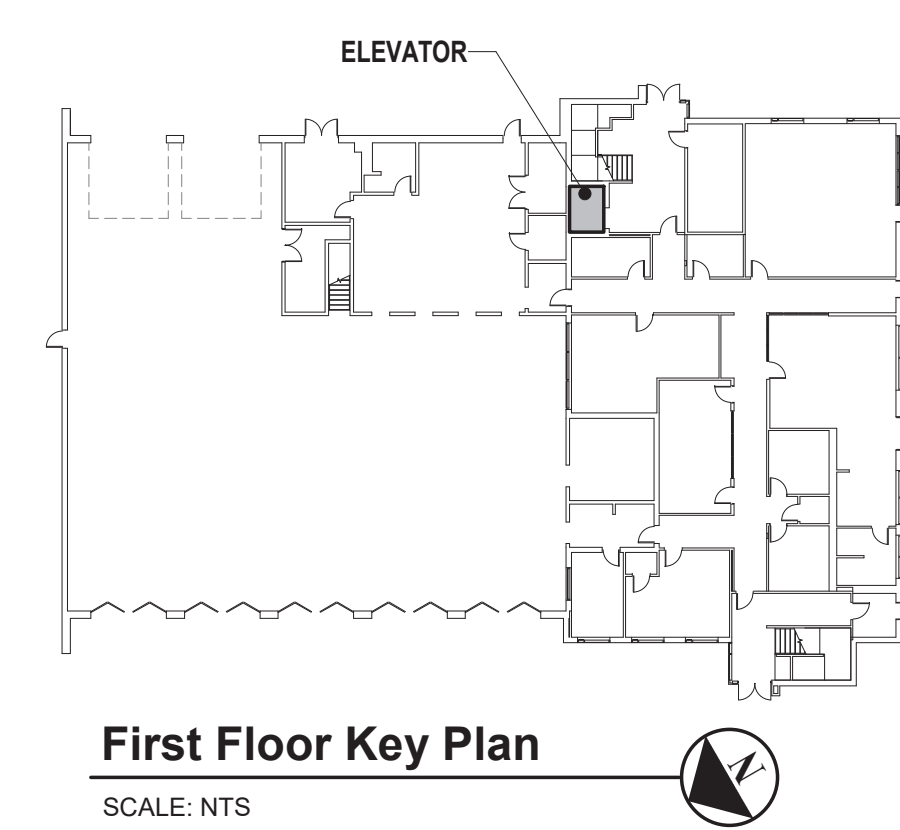


Elevator Pit Ladder Detail

SCALE: 1/2" = 1'-0"

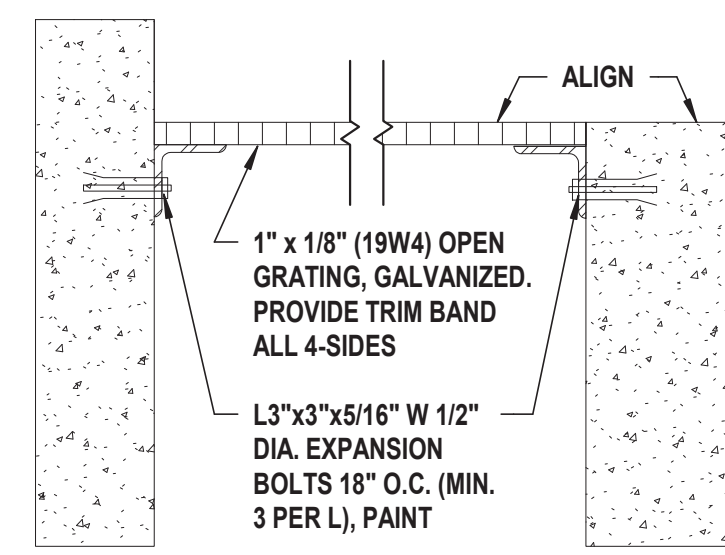


Sump Pit Cover Detail

SCALE: 1 1/2" = 1'-0"

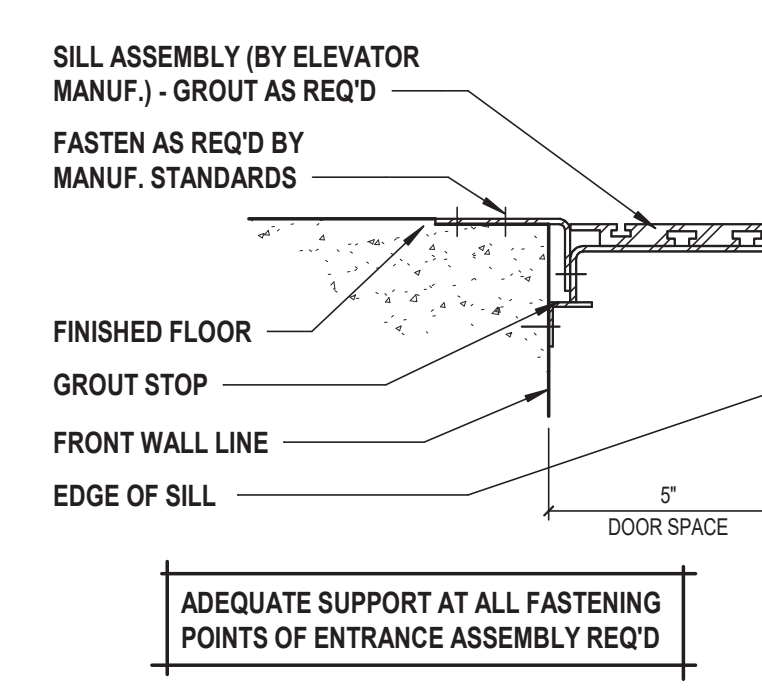


Elevator Sill Detail

SCALE: 3" = 1'-0"

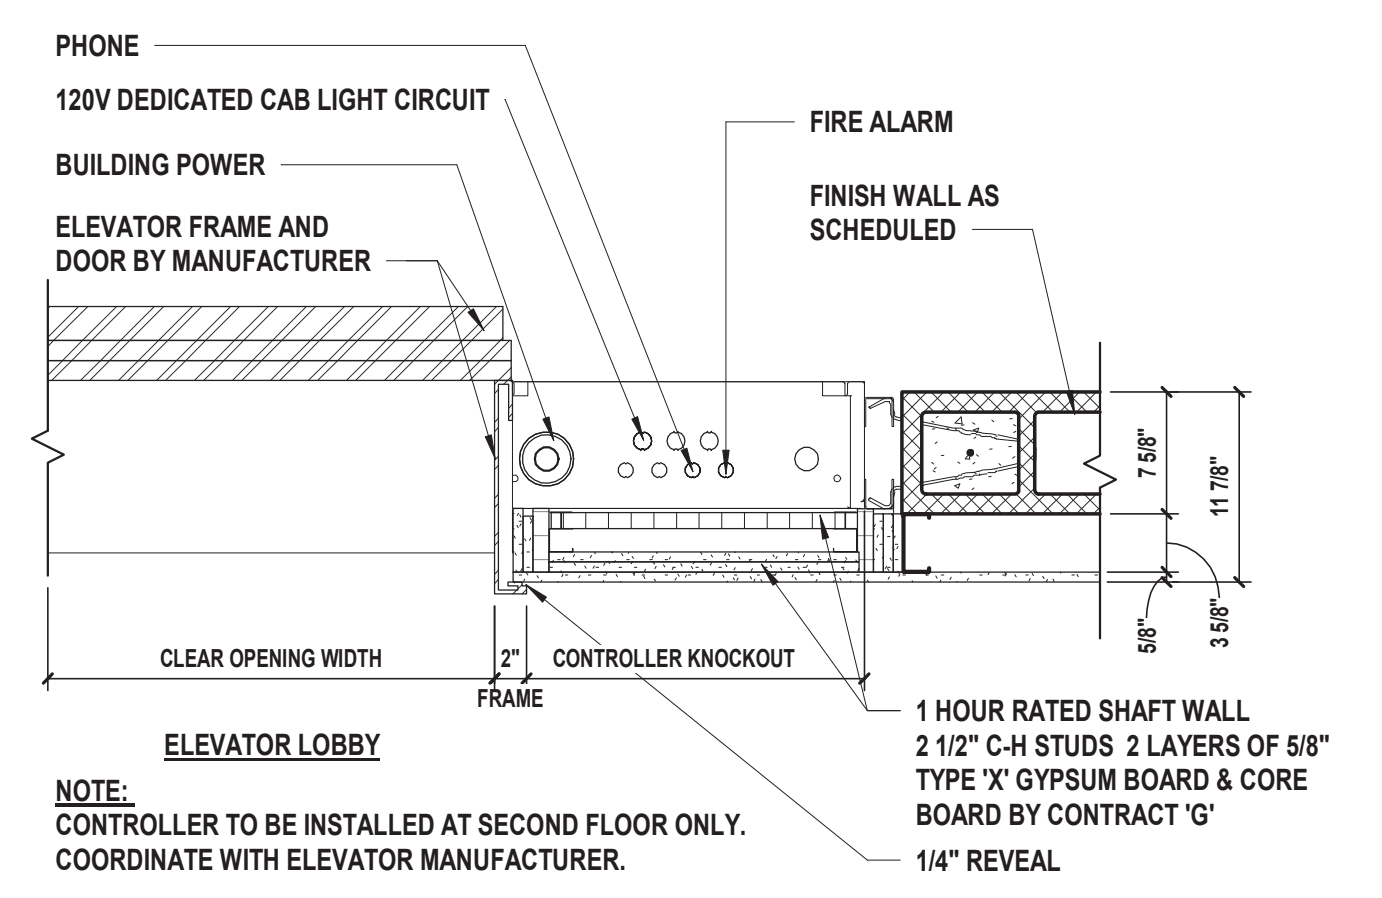


Entrance Plan View - Sim.

SCALE: 1" = 1'-0"

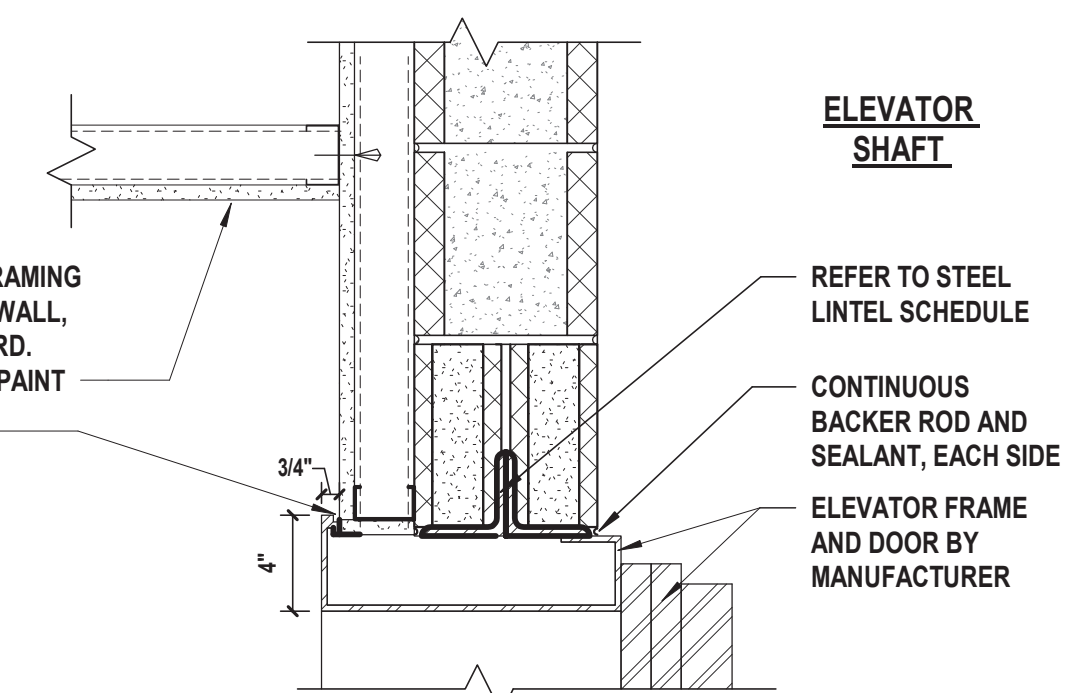


Elevator Door Head Detail

SCALE: 1 1/2" = 1'-0"

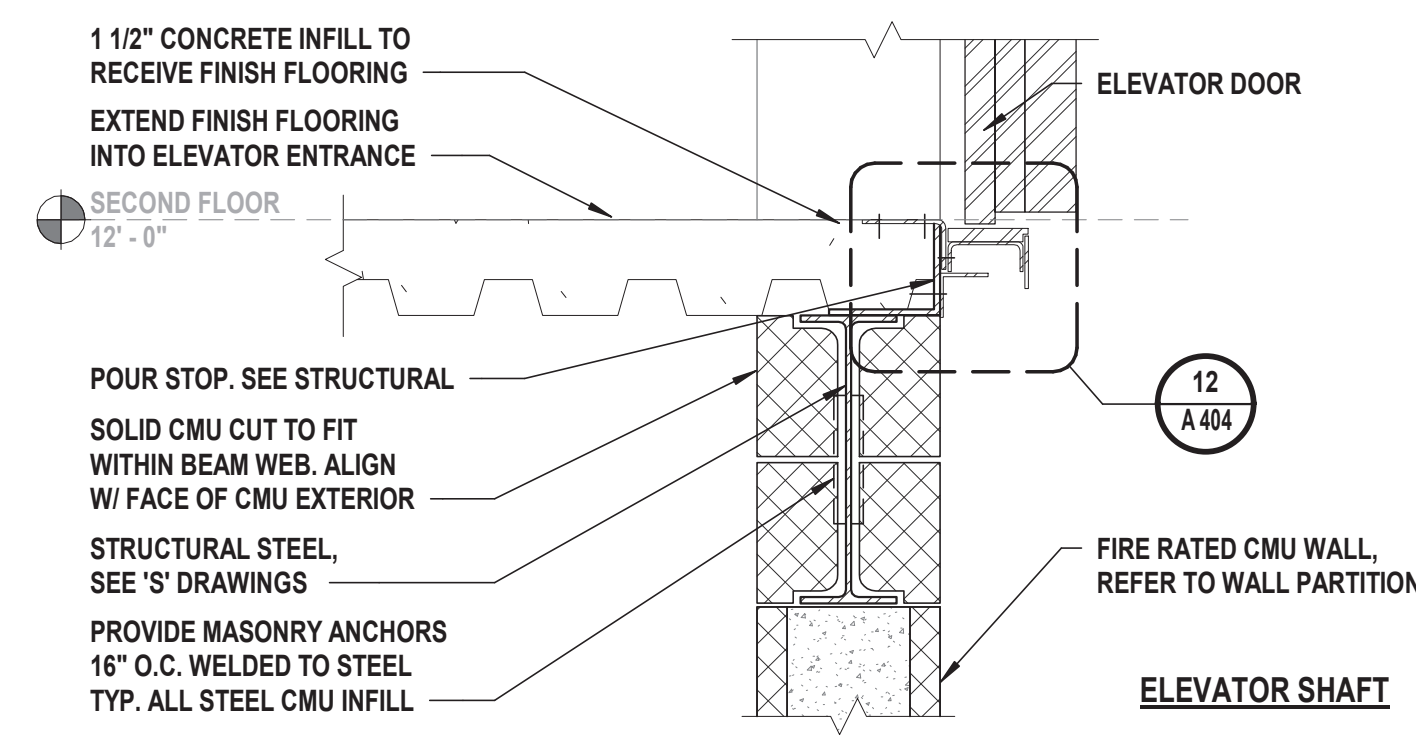


Elevator Door Threshold @ Concrete Floor

SCALE: 1 1/2" = 1'-0"

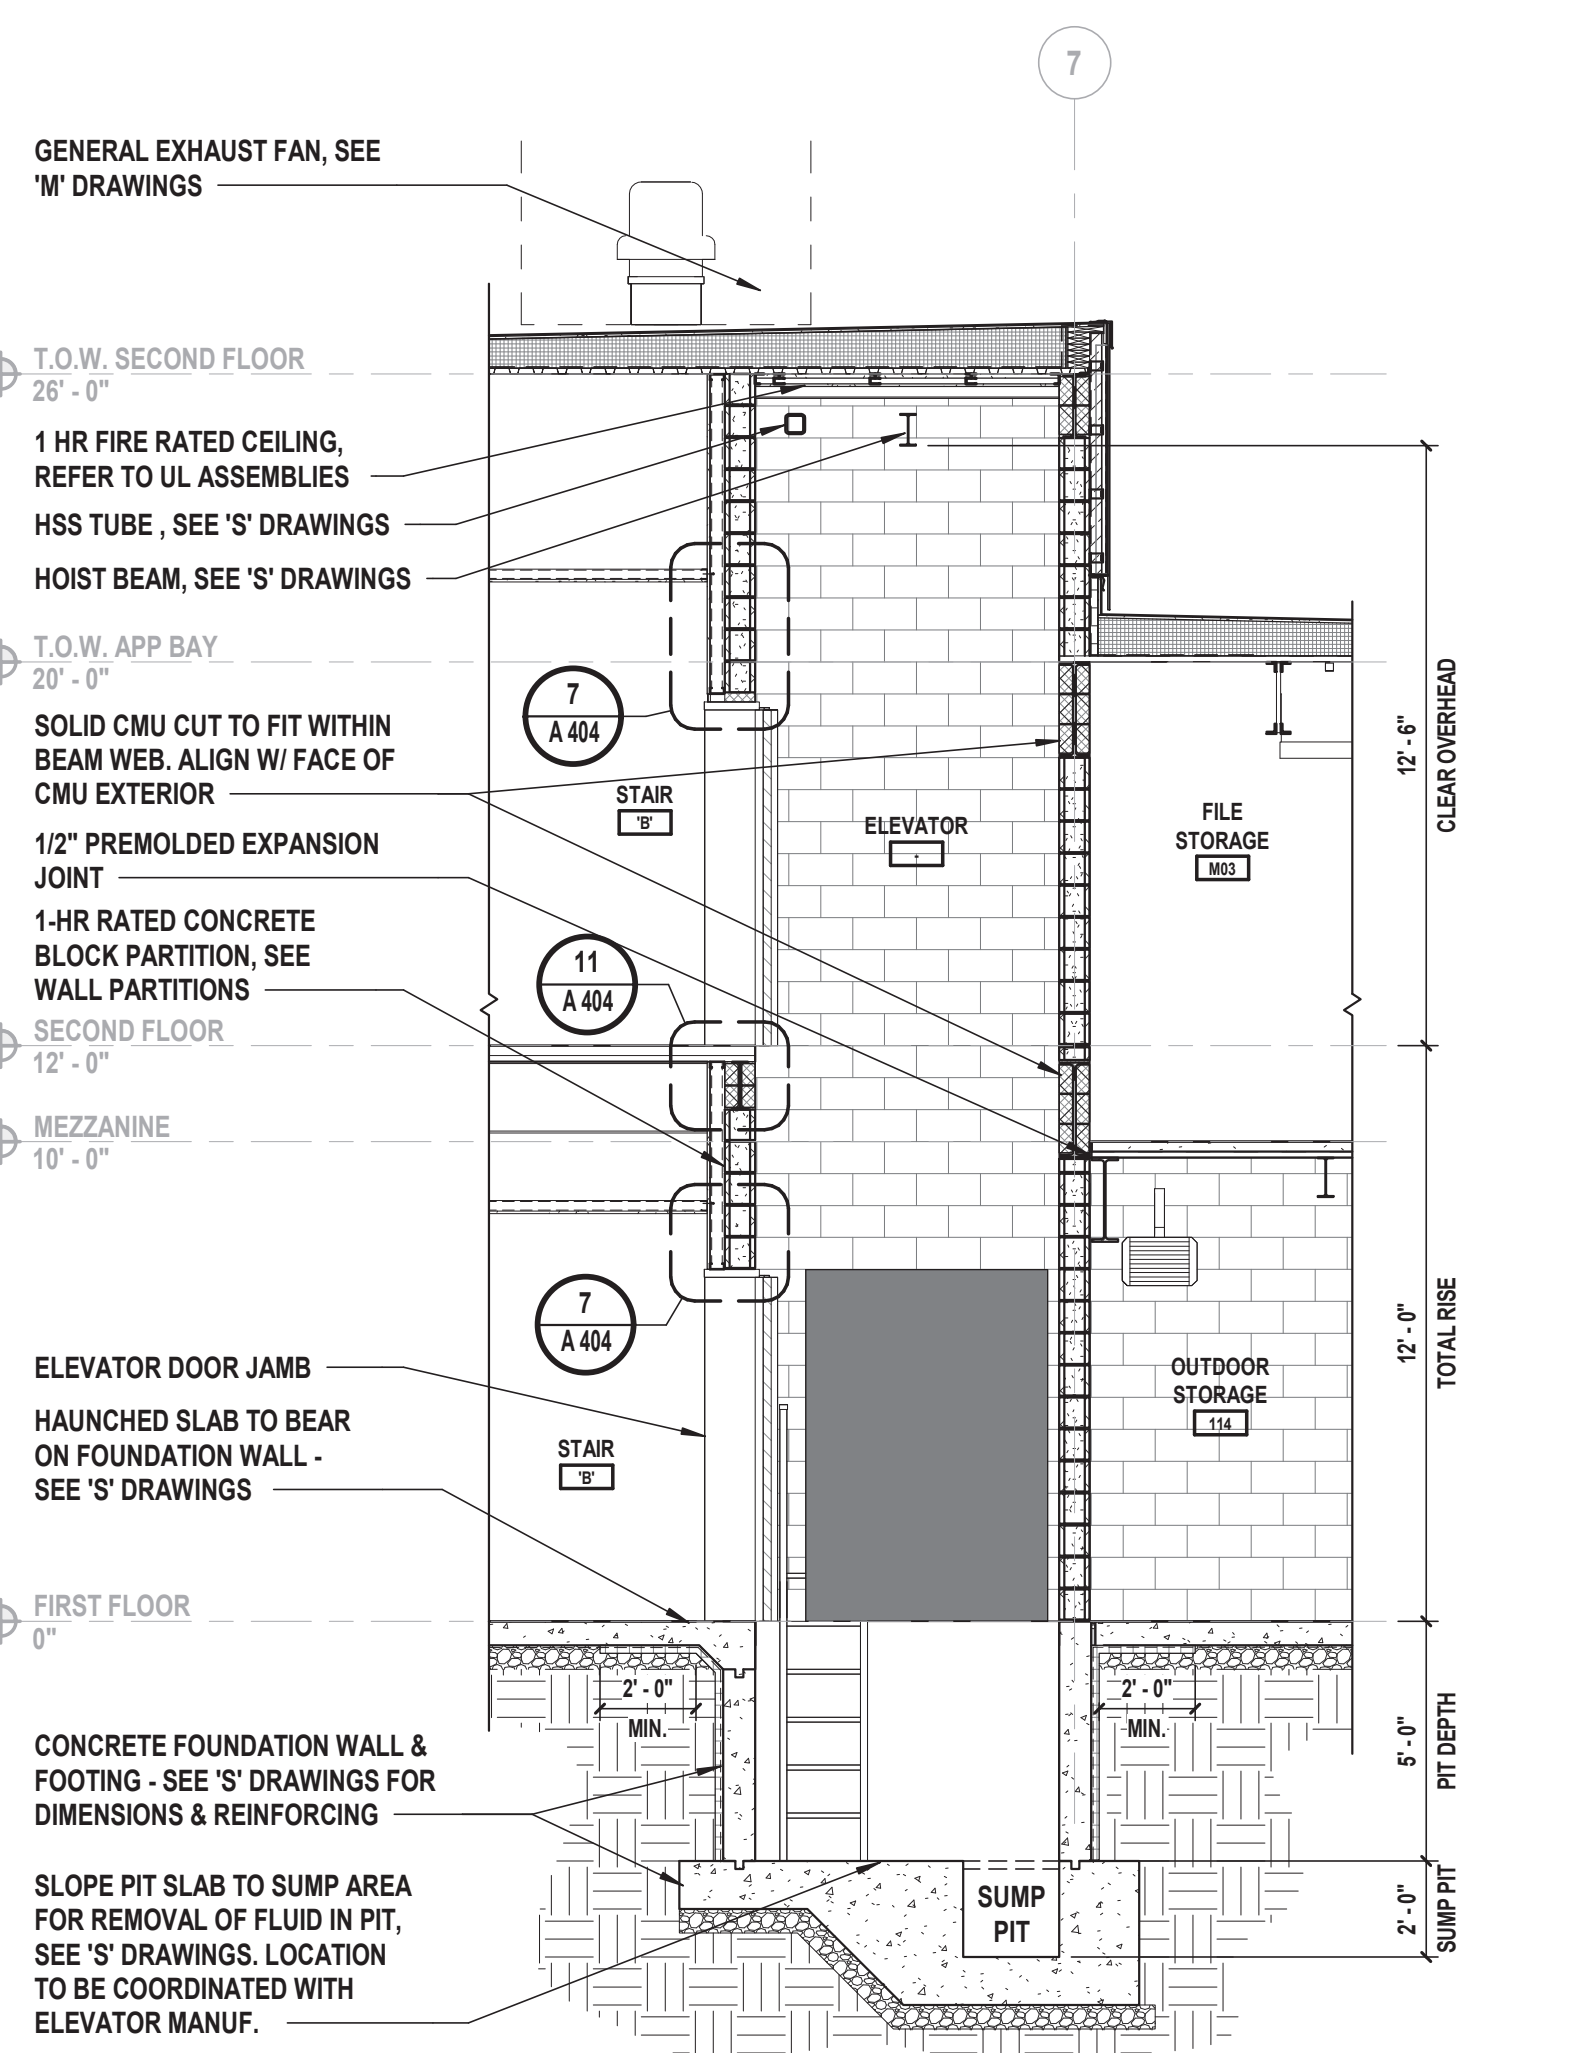

Elevator Section

SCALE: 1/4" = 1'-0"

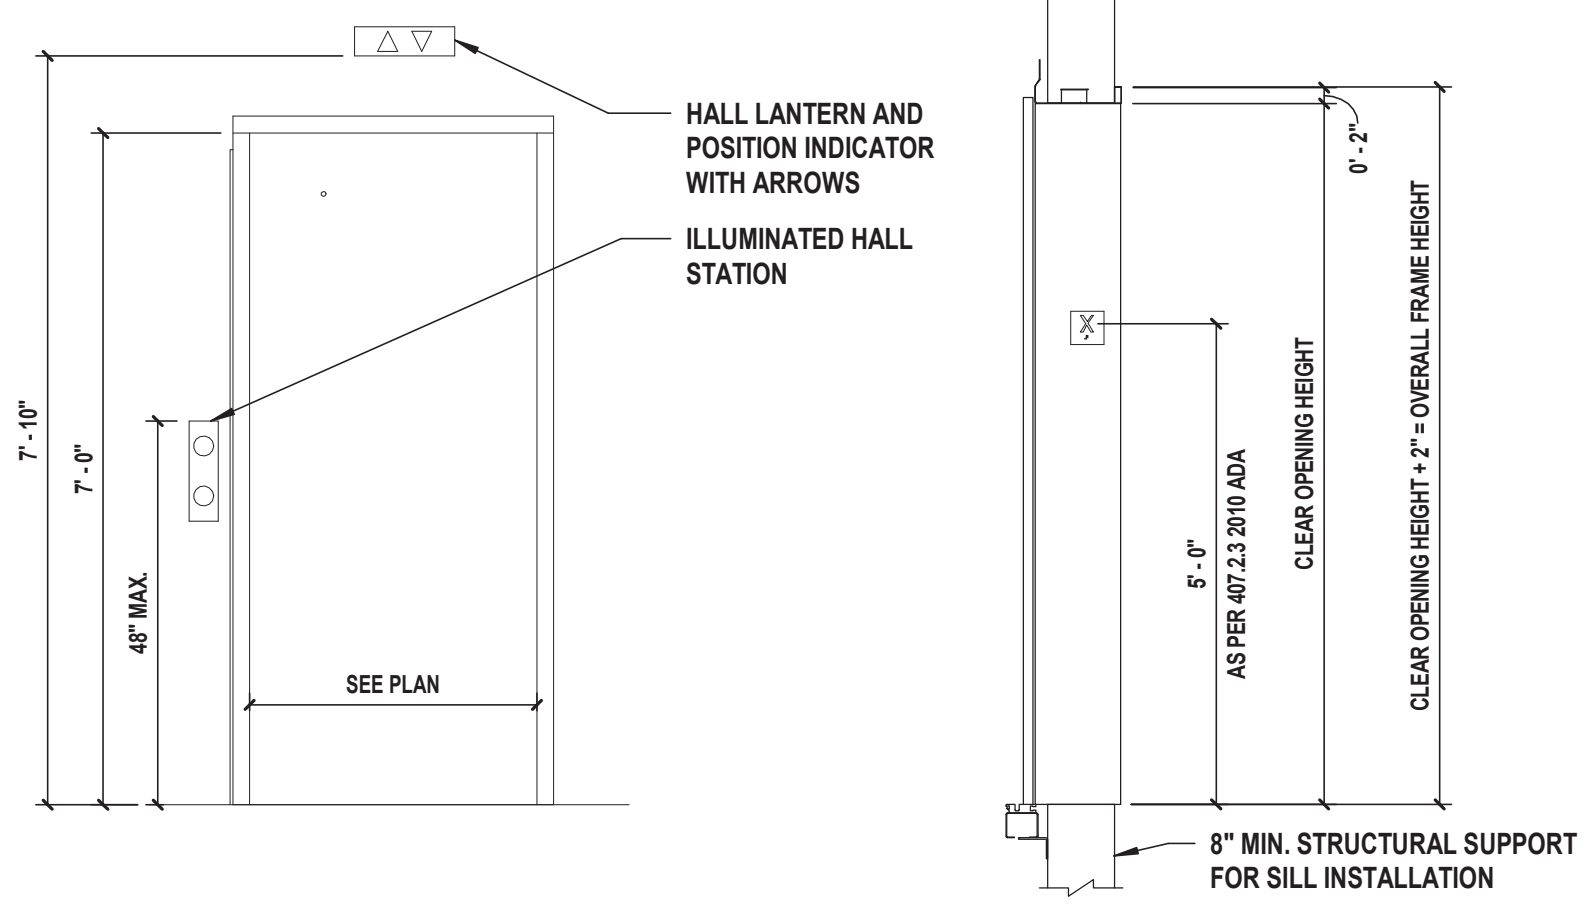

Entrance Side View

SCALE: 1/2" = 1'-0"

Entrance Elevation View

SCALE: 1/2" = 1'-0"

CONSULTANTS:		

MARK	DATE	DESCRIPTION

REGISTERED ARCHITECT
PATRICK O. STONE
STATE OF NEW YORK
029654


PATRICK O. STONE, R.A.
NY PROFESSIONAL ARCHITECT LIC. NO. 029654

10/31/2025
Exp. Date

DESIGNED BY: DBS/RLG
PROJECT No: TRFD 2302

DRAWN BY: ANK
DATE: FEBRUARY 2025

CHECKED BY: DBS
SCALE: AS SHOWN

REVIEWED BY: POS

CLIENT

THIELLS
ROSEVILLE FIRE
DISTRICT

NEW 26-100 FIRE
HEADQUARTERS



65 W RAMAPO ROAD
GARNERVILLE, NY 10923

CONTRACT

CONTRACT G
GENERAL CONSTRUCTION

STATUS


FINAL BID DOCUMENT

SHEET TITLE


ENLARGED TOILET ROOMS,
INTERIOR ELEVATIONS & TYPICAL
DETAILS

DRAWING No.


A 410.00

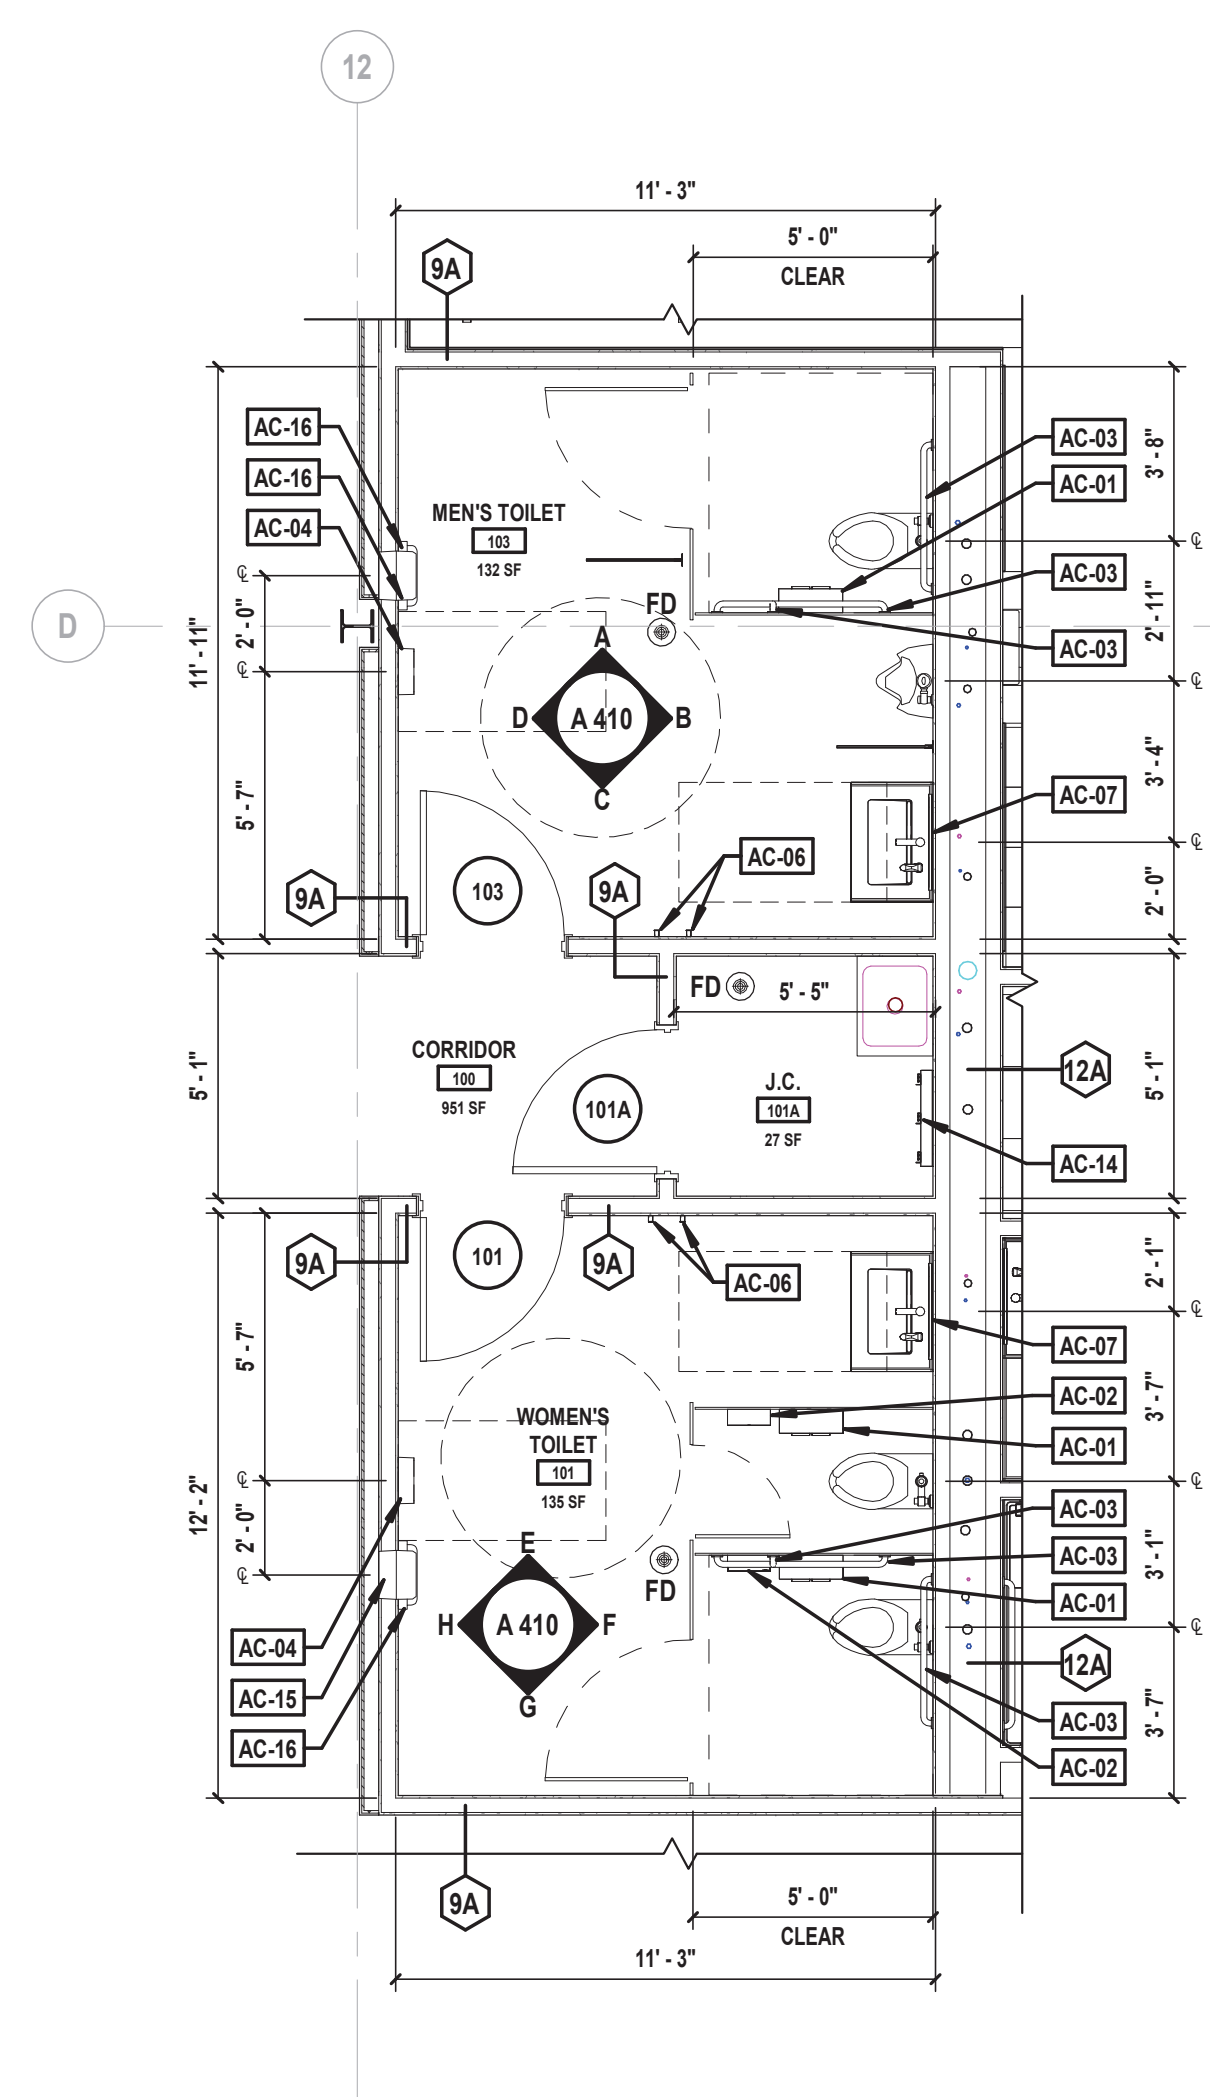


1 Enlarged First Floor Toilet Room Plans
SCALE: 1/4" = 1'-0"
NOTE: REFER TO SHEET A 412 FOR TYPICAL TILE LAYOUTS, NOTES, DETAILS AND ACCESSORY SCHEDULE.

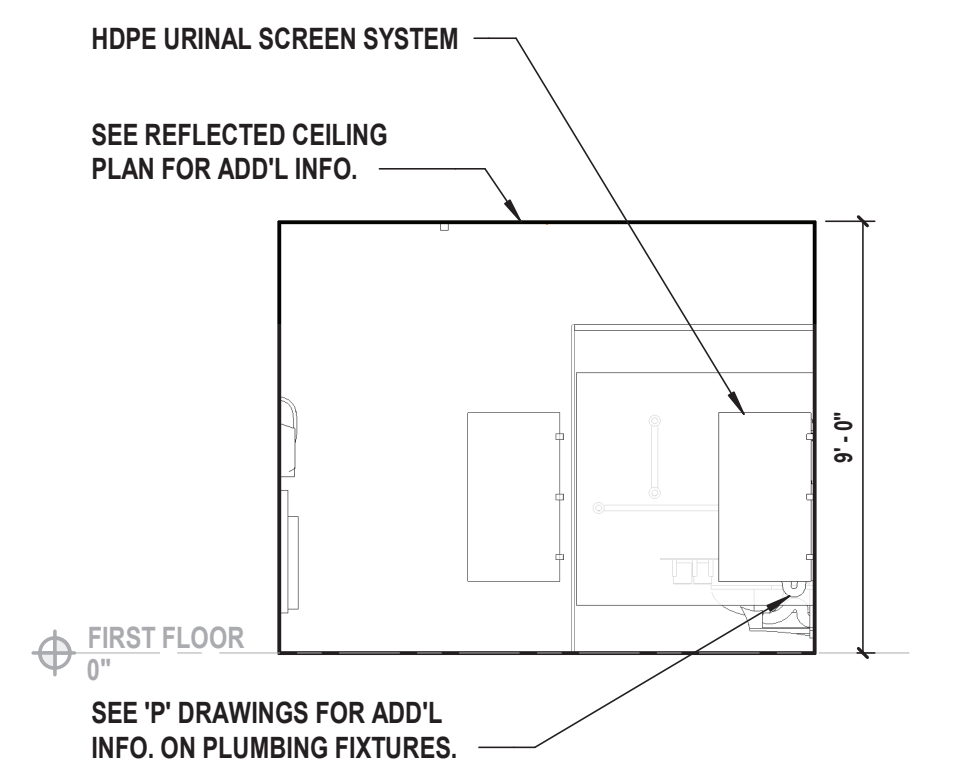


A Interior Elevation
SCALE: 1/4" = 1'-0"

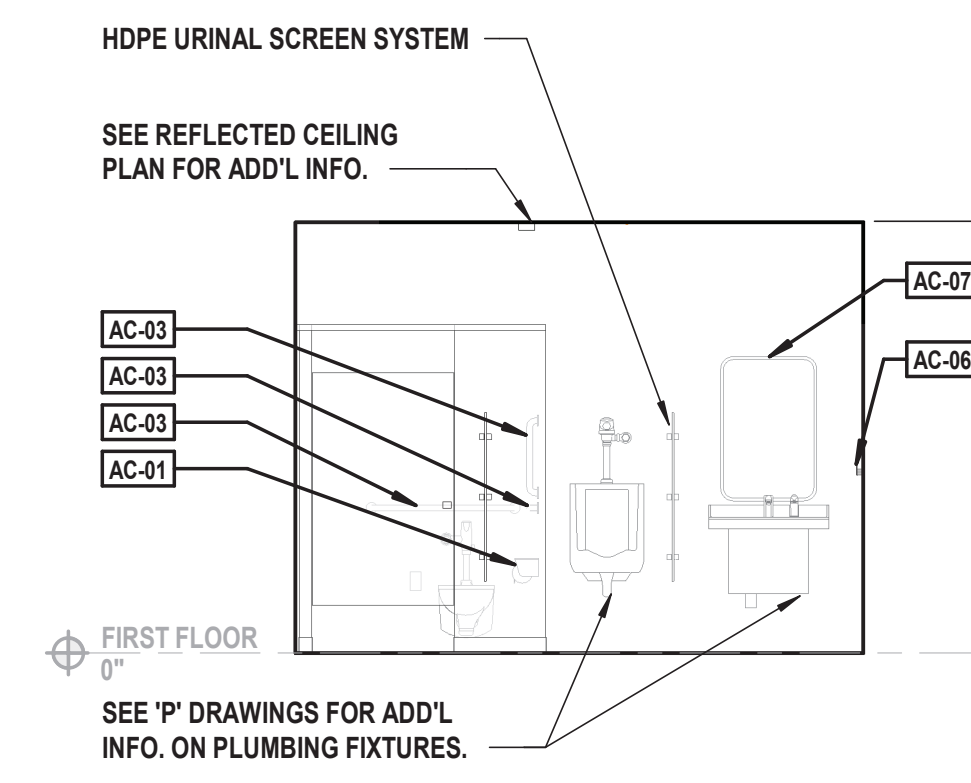


B Interior Elevation
SCALE: 1/4" = 1'-0"

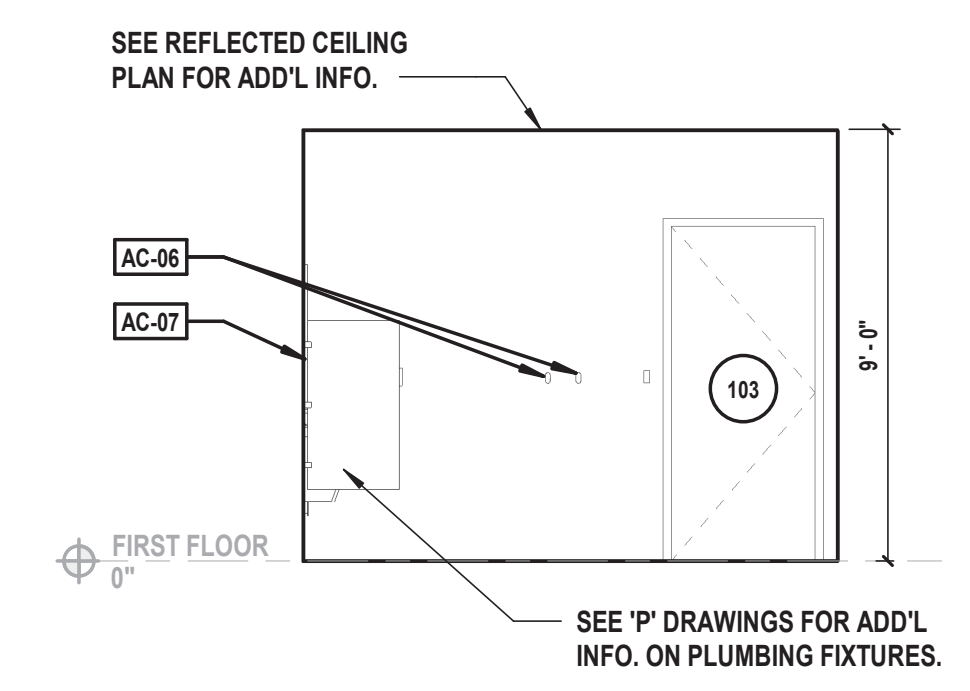


C Interior Elevation
SCALE: 1/4" = 1'-0"

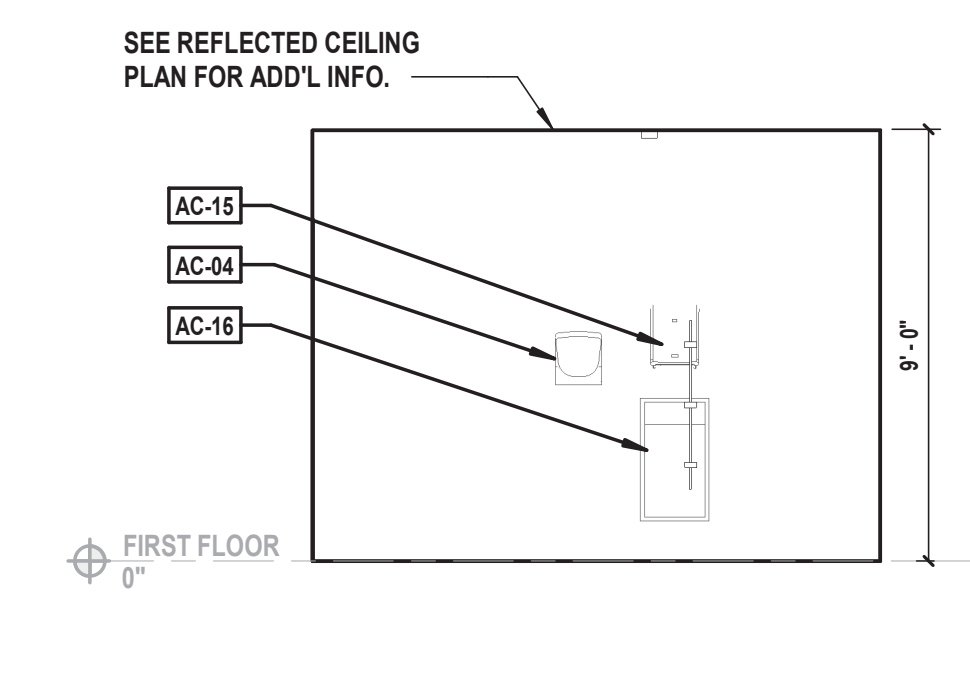


D Interior Elevation
SCALE: 1/4" = 1'-0"

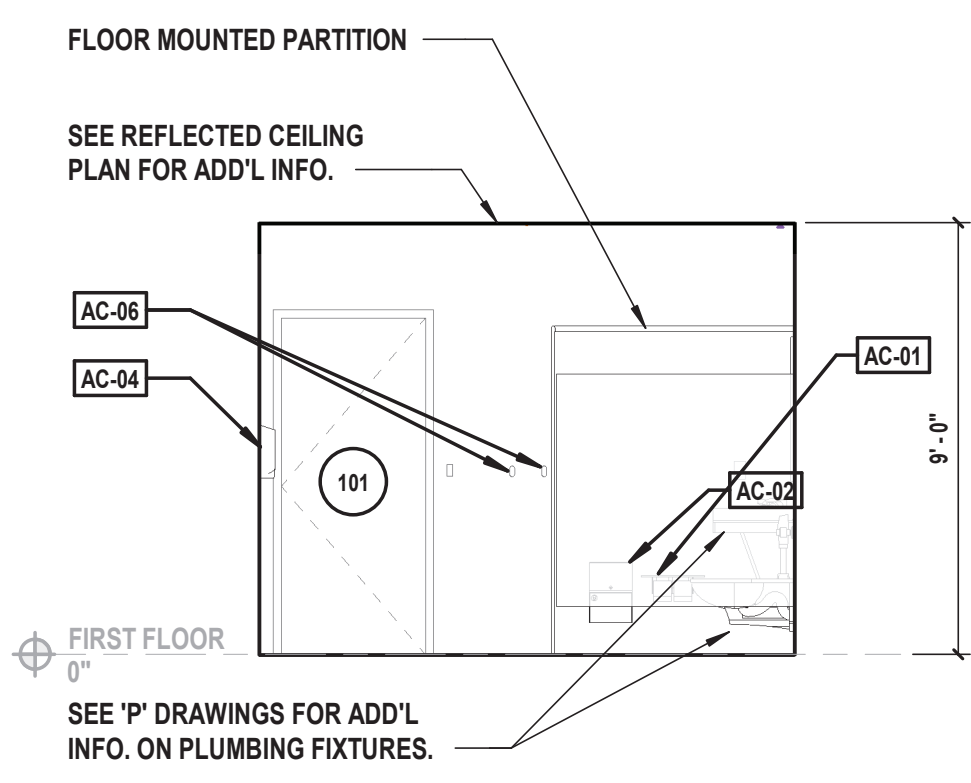


E Interior Elevation
SCALE: 1/4" = 1'-0"

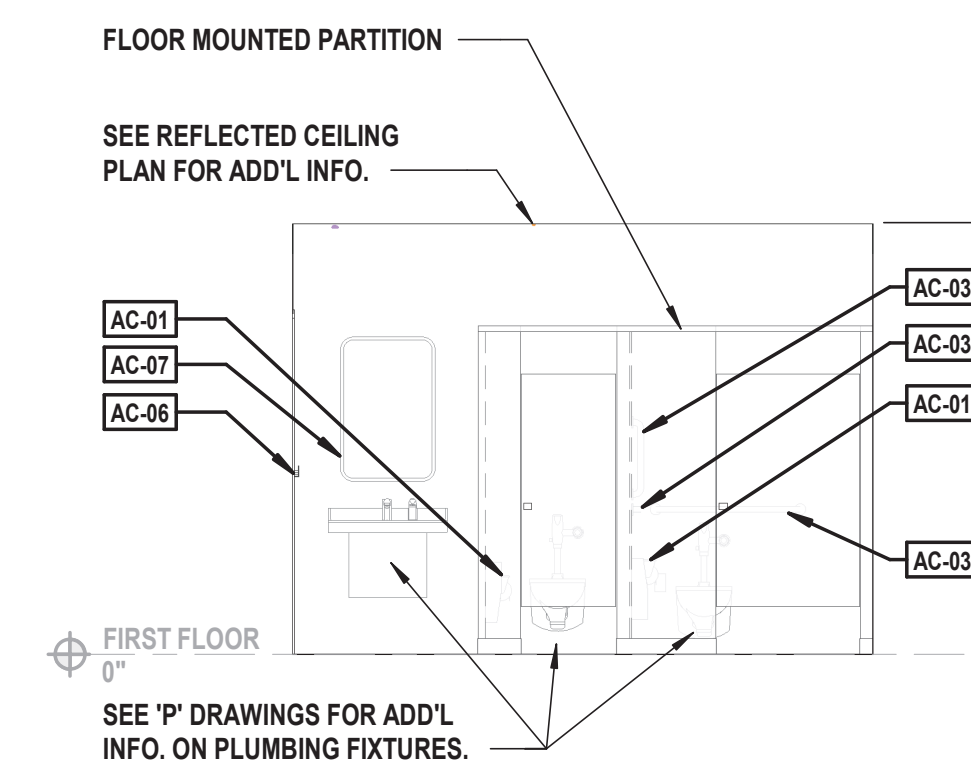


F Interior Elevation
SCALE: 1/4" = 1'-0"

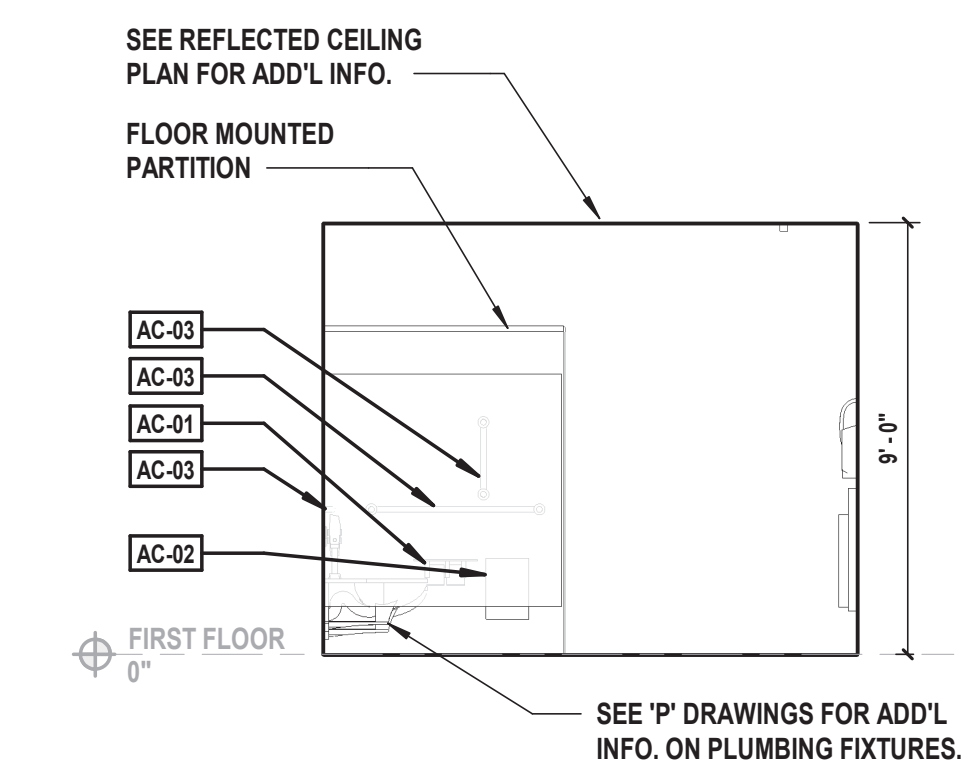


G Interior Elevation
SCALE: 1/4" = 1'-0"

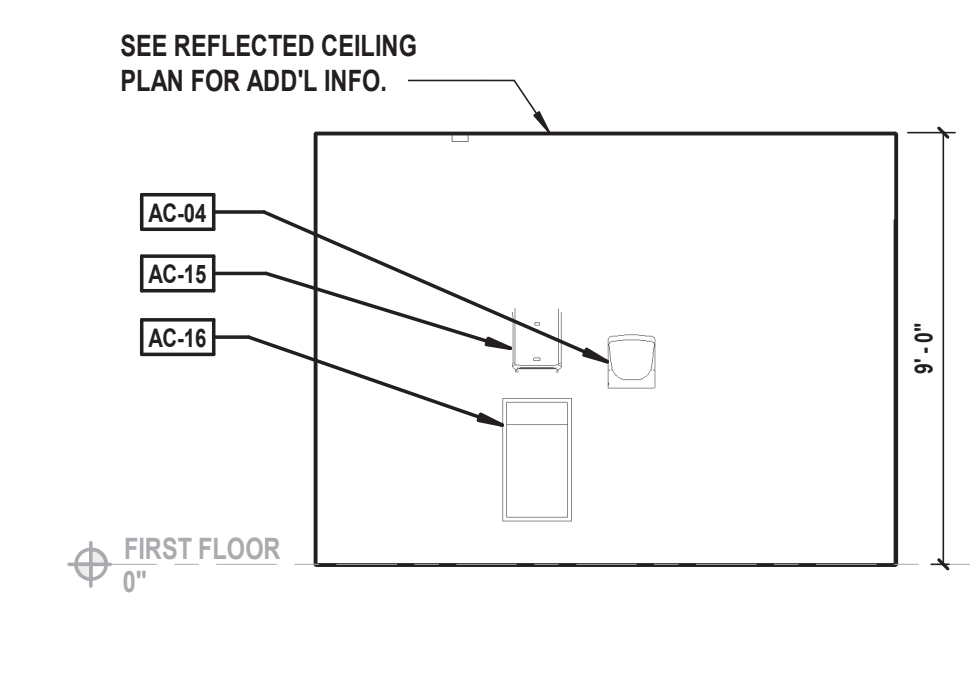


H Interior Elevation
SCALE: 1/4" = 1'-0"

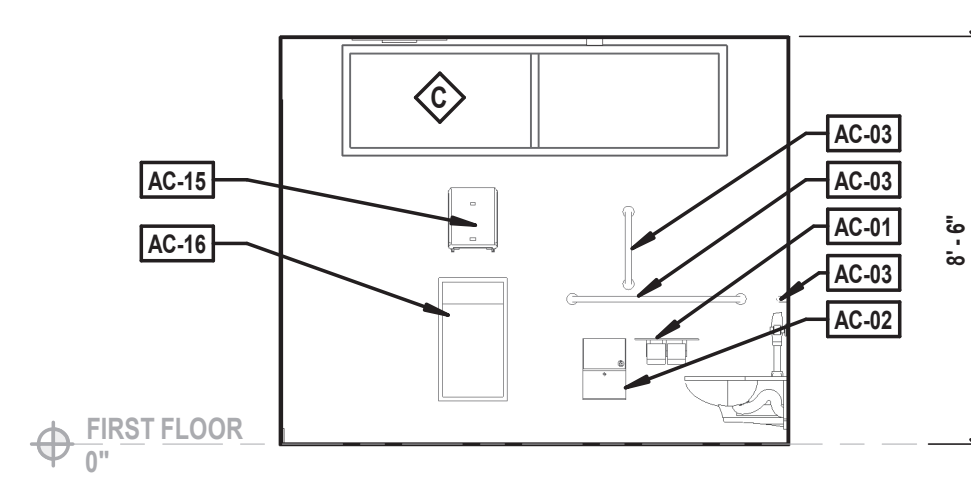


I Interior Elevation
SCALE: 1/4" = 1'-0"

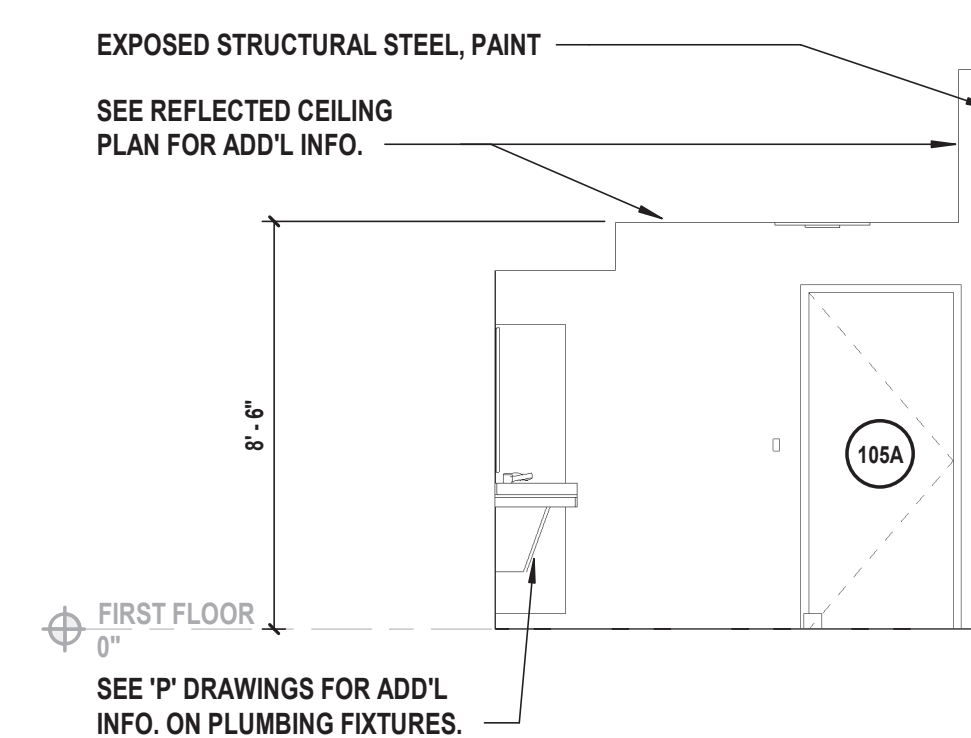


J Interior Elevation
SCALE: 1/4" = 1'-0"

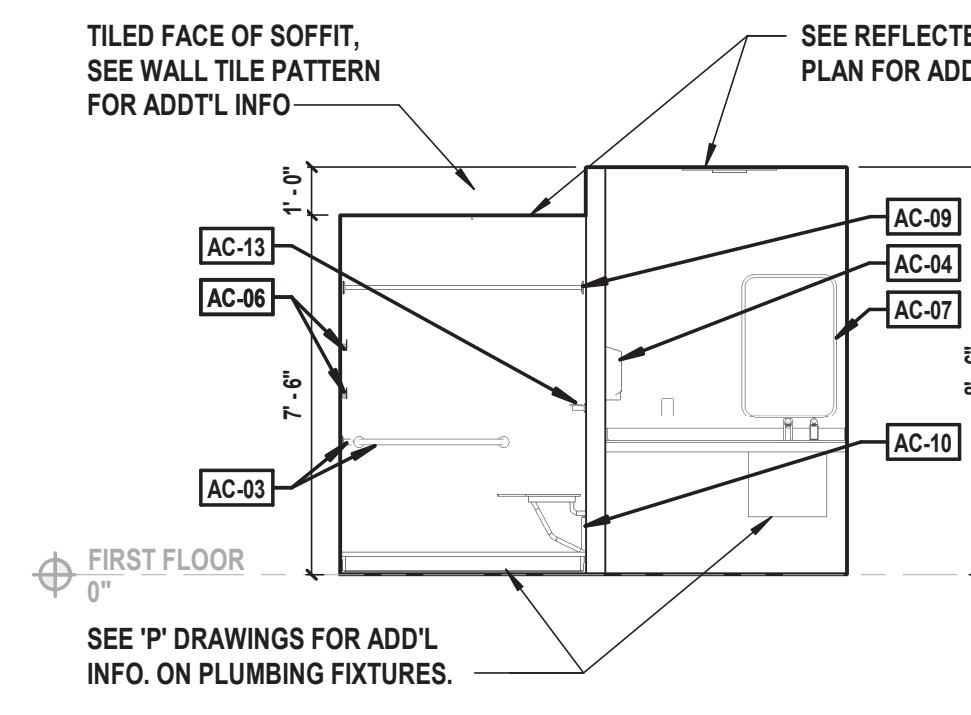


K Interior Elevation
SCALE: 1/4" = 1'-0"

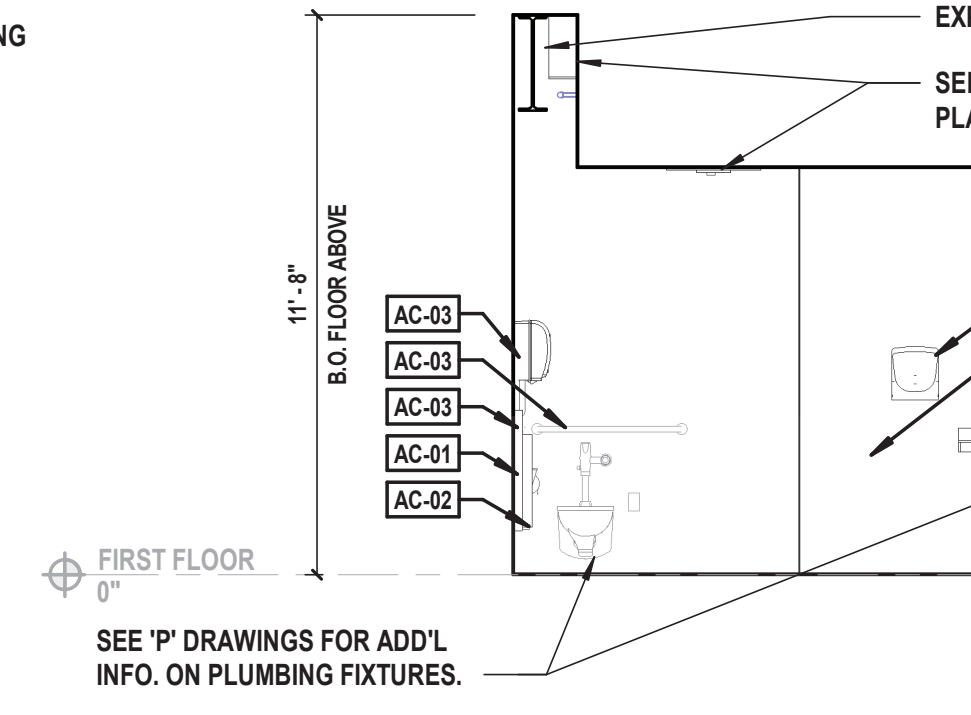

L Interior Elevation
SCALE: 1/4" = 1'-0"

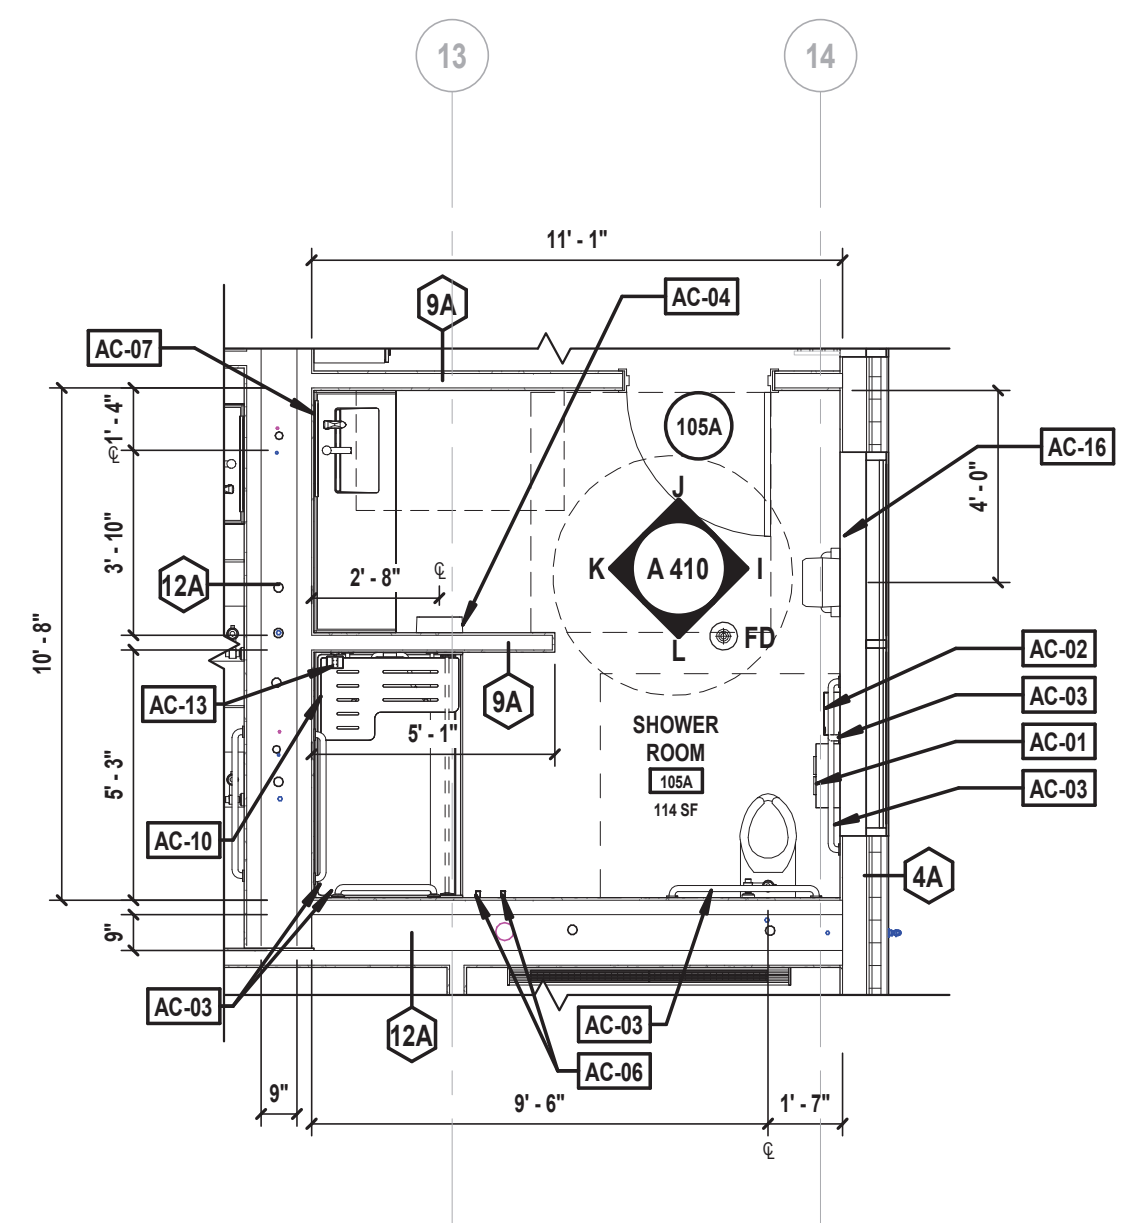

2 Enlarged Shower Room Plan
SCALE: 1/4" = 1'-0"
NOTE: REFER TO SHEET A 412 FOR TYPICAL TILE LAYOUTS, NOTES, DETAILS AND ACCESSORY SCHEDULE.

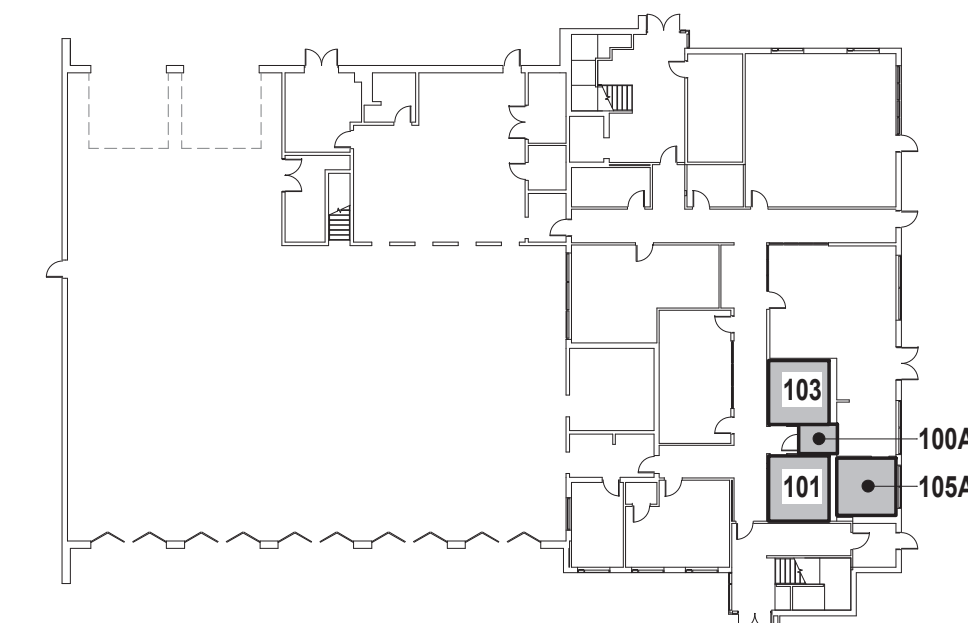

First Floor Key Plan
SCALE: NTS

		10/31/2025 Exp. Date	
		PATRICK O. STONE, R.A. NY PROFESSIONAL ARCHITECT LIC. NO. 039654 "IN ACCORDANCE WITH ARTICLE 138 OF THE EDUCATION LAW, ALTERATION OF THIS DOCUMENT EXCEPT BY A REGISTERED PROFESSIONAL IS ILLEGAL."	
DESIGNED BY:	DRAWN BY:	CHECKED BY:	REVIEWED BY:
DBS/RLG	ANK	DBS	POS
PROJECT NO:	DATE:	SCALE:	
TRFD 2302	FEBRUARY 2025	AS SHOWN	

**THIELS
ROSEVILLE FIRE
DISTRICT**



CONTRACT



**CONTRACT G
GENERAL CONSTRUCTION**

STATUS	FINAL BID DOCUMENT
--------	--------------------

SHEET TITLE

**ENLARGED TOILET ROOMS,
INTERIOR ELEVATIONS & TYPICAL
DETAILS**

  DRAWING No. **A 411.00**





The diagram is a detailed floor plan of the SCBA room. It shows a rectangular room with a door on the left wall. Key features include:

- Dimensions:** Overall width is 12'-0" and overall depth is 16'-1". Internal dimensions show a door width of 7'-5" and a room depth of 13'-1" from the door to the back wall.
- Equipment:** A SCBA unit (121, 128 SF) is located near the door. A fire detector (FD) is mounted on the wall. A fire extinguisher (A 420) is also indicated.
- Storage:** A cabinet (21-91A) is positioned against the right wall. A bench or storage unit (8B) is located near the door.
- Other Labels:** 121-04, 121-02, 21-91A, 8B, 8C, 8E, 8F, 8G, 11-4, 12-4, 13-4, 99-4, 100-4.

STRUCTURAL MEMBERS, SEE 'S' DRAWINGS FOR ADD'L INFO.

115-02

115A

115-03

115

0"

SEE 'P' DRAWINGS FOR ADD'L INFO. ON PLUMBING FIXTURES.

Interior Elevation

SCALE: 1/4" = 1'-0"

ELECTRIC UNIT HEATER, SEE 'M' DRAWINGS
 115-01
 115-04
 FIRST FLOOR
 0"
 SCALE: 1/4" = 1'-0"

[illegible]

ELECTRIC UNIT HEATER, SEE 'M' DRAWINGS

STRUCTURAL MEMBER, SEE 'S' DRAWINGS FOR ADD'L INFO.

115-04

115-01

115-02

0" 1'-0"

FIRST FLOOR

D Interior Elevation

SCALE: 1/4" = 1'-0"


SEE 'M' DRAWINGS FOR
ADD'L INFO ON
MECHANICAL EQUIPMENT

8'-0"

FIRST FLOOR
0"

F Interior Elevation

SCALE: 1/4" = 1'-0"

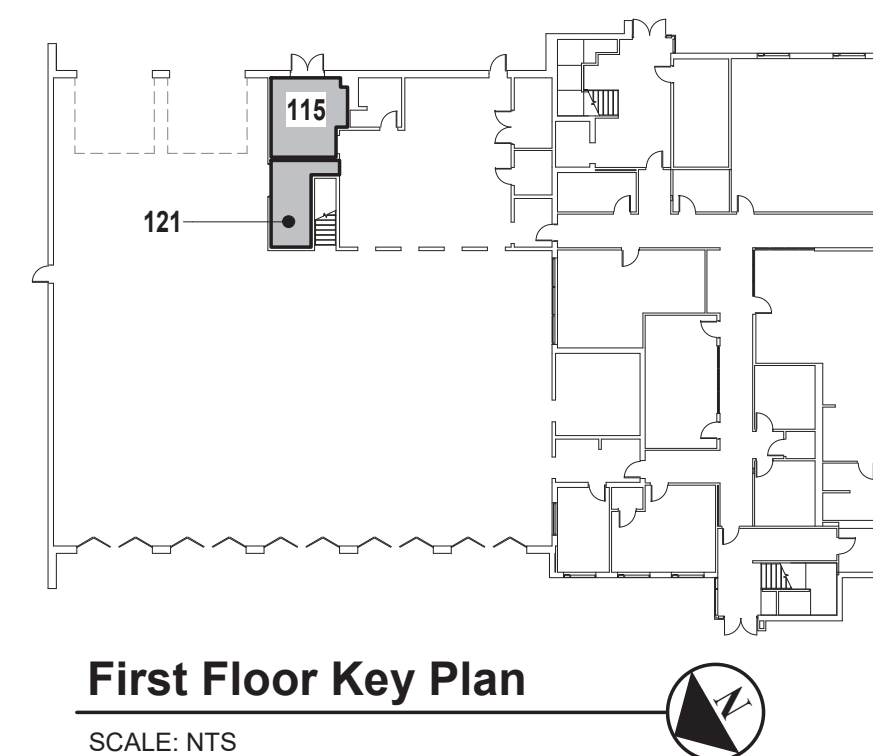

CONSULTANTS:		

MARK	DATE	DESCRIPTION

REGISTERED ARCHITECT
PATRICK O. STONE
STATE OF NEW YORK
029654


PATRICK O. STONE, R.A.
NY PROFESSIONAL ARCHITECT LIC. NO. 029654

10/31/2025
Exp. Date

"IN ACCORDANCE WITH ARTICLE 145, SECTION 1209 OF THE NYS EDUCATION LAW,
ALTACTION OF THIS DOCUMENT EXCEPT BY A LICENSED PROFESSIONAL IS ILLEGAL."

DESIGNED BY: DBS/RLG
PROJECT No: TRFD 2302

DRAWN BY: ANK
DATE: FEBRUARY 2025

CHECKED BY: DBS
SCALE: AS SHOWN

REVIEWED BY: POS

CLIENT

THIELLS
ROSEVILLE FIRE
DISTRICT

NEW 26-100 FIRE
HEADQUARTERS



65 W RAMAPO ROAD
GARNERVILLE, NY 10923

CONTRACT

CONTRACT G
GENERAL CONSTRUCTION

STATUS


FINAL BID DOCUMENT

SHEET TITLE

ENLARGED DECON TRANSITIONS
& WORK ROOM PLANS &
INTERIOR ELEVATIONS


DRAWING No.

A 421.00

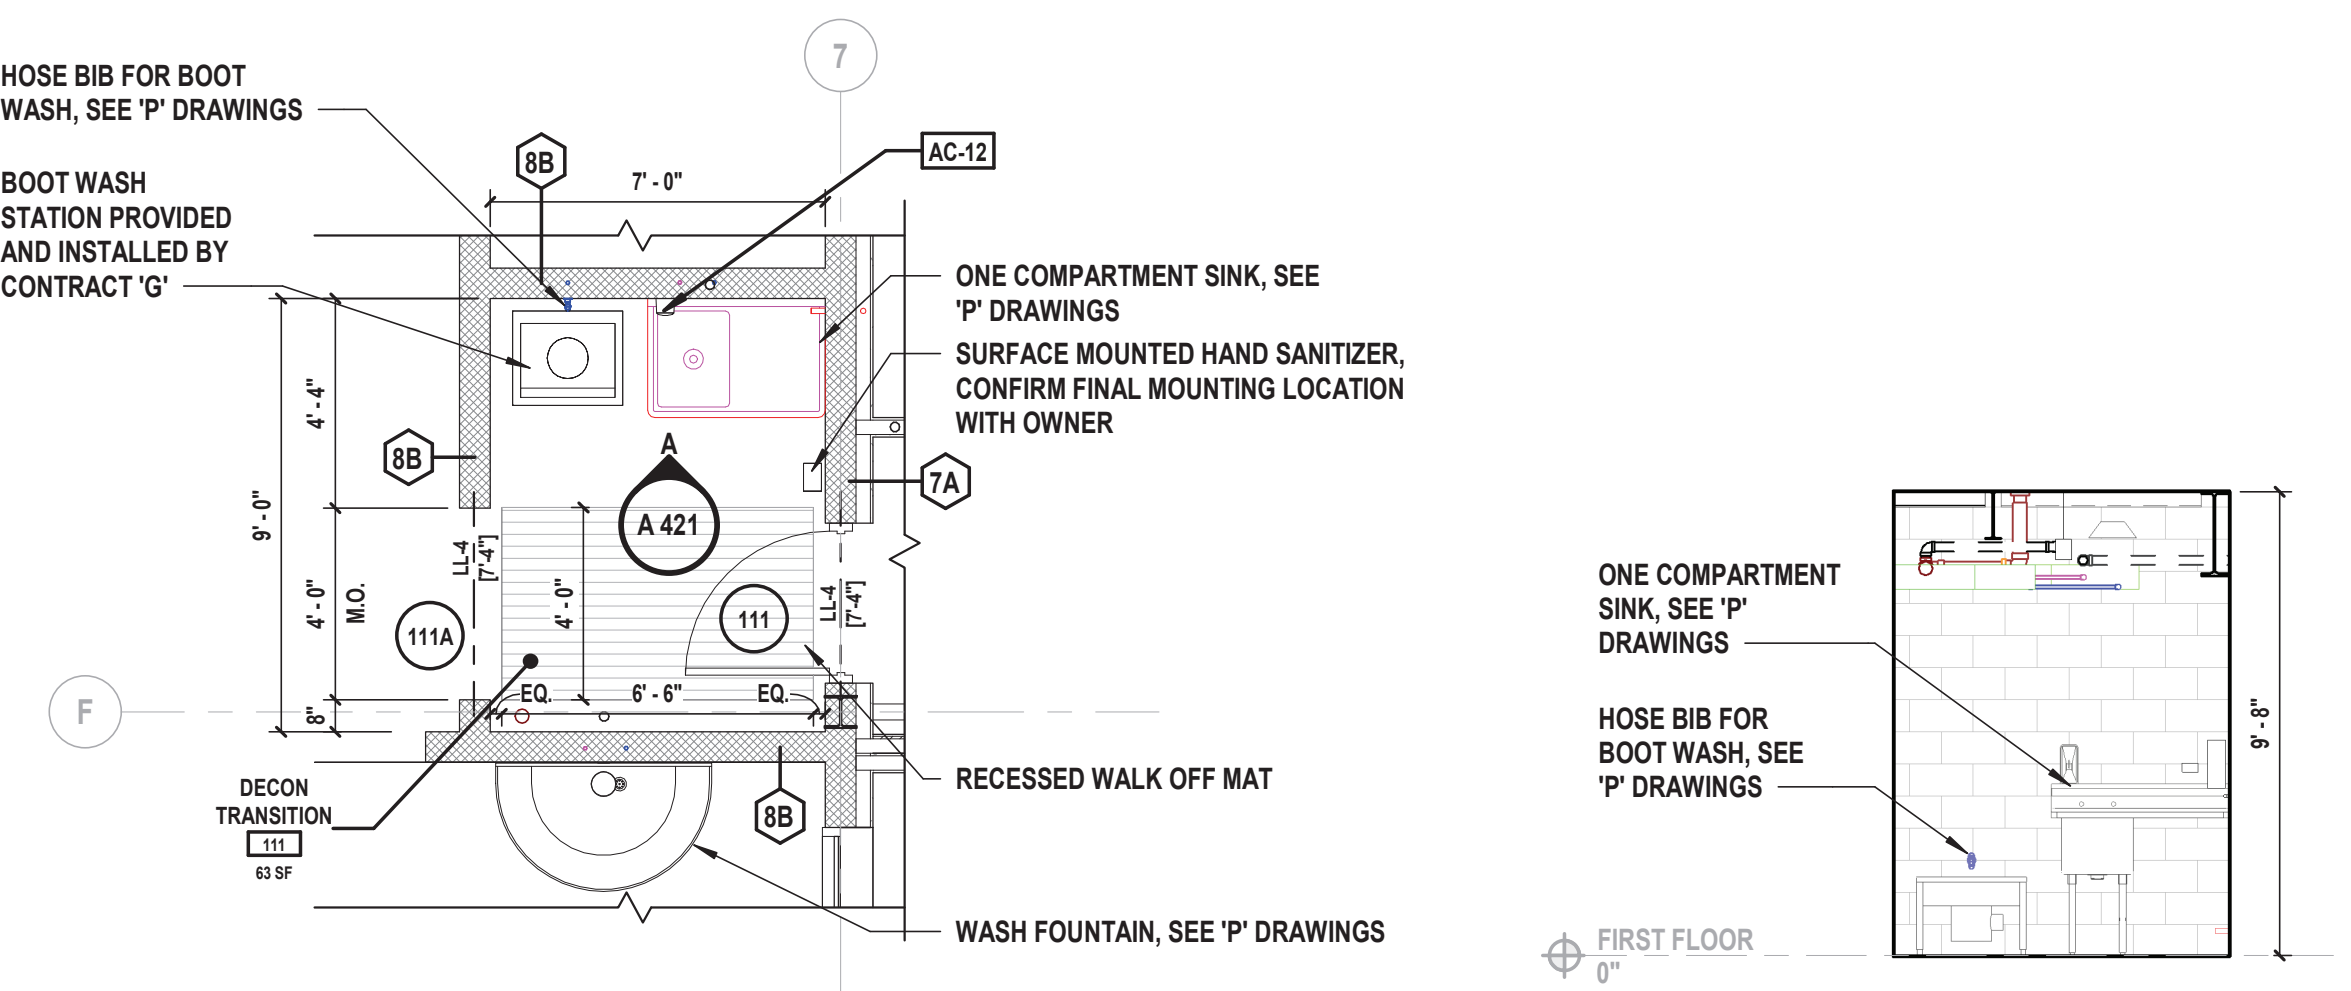


6 Enlarged Decon Transition Plan - 111
SCALE: 1/4" = 1'-0"

A Interior Elevation
SCALE: 1/4" = 1'-0"

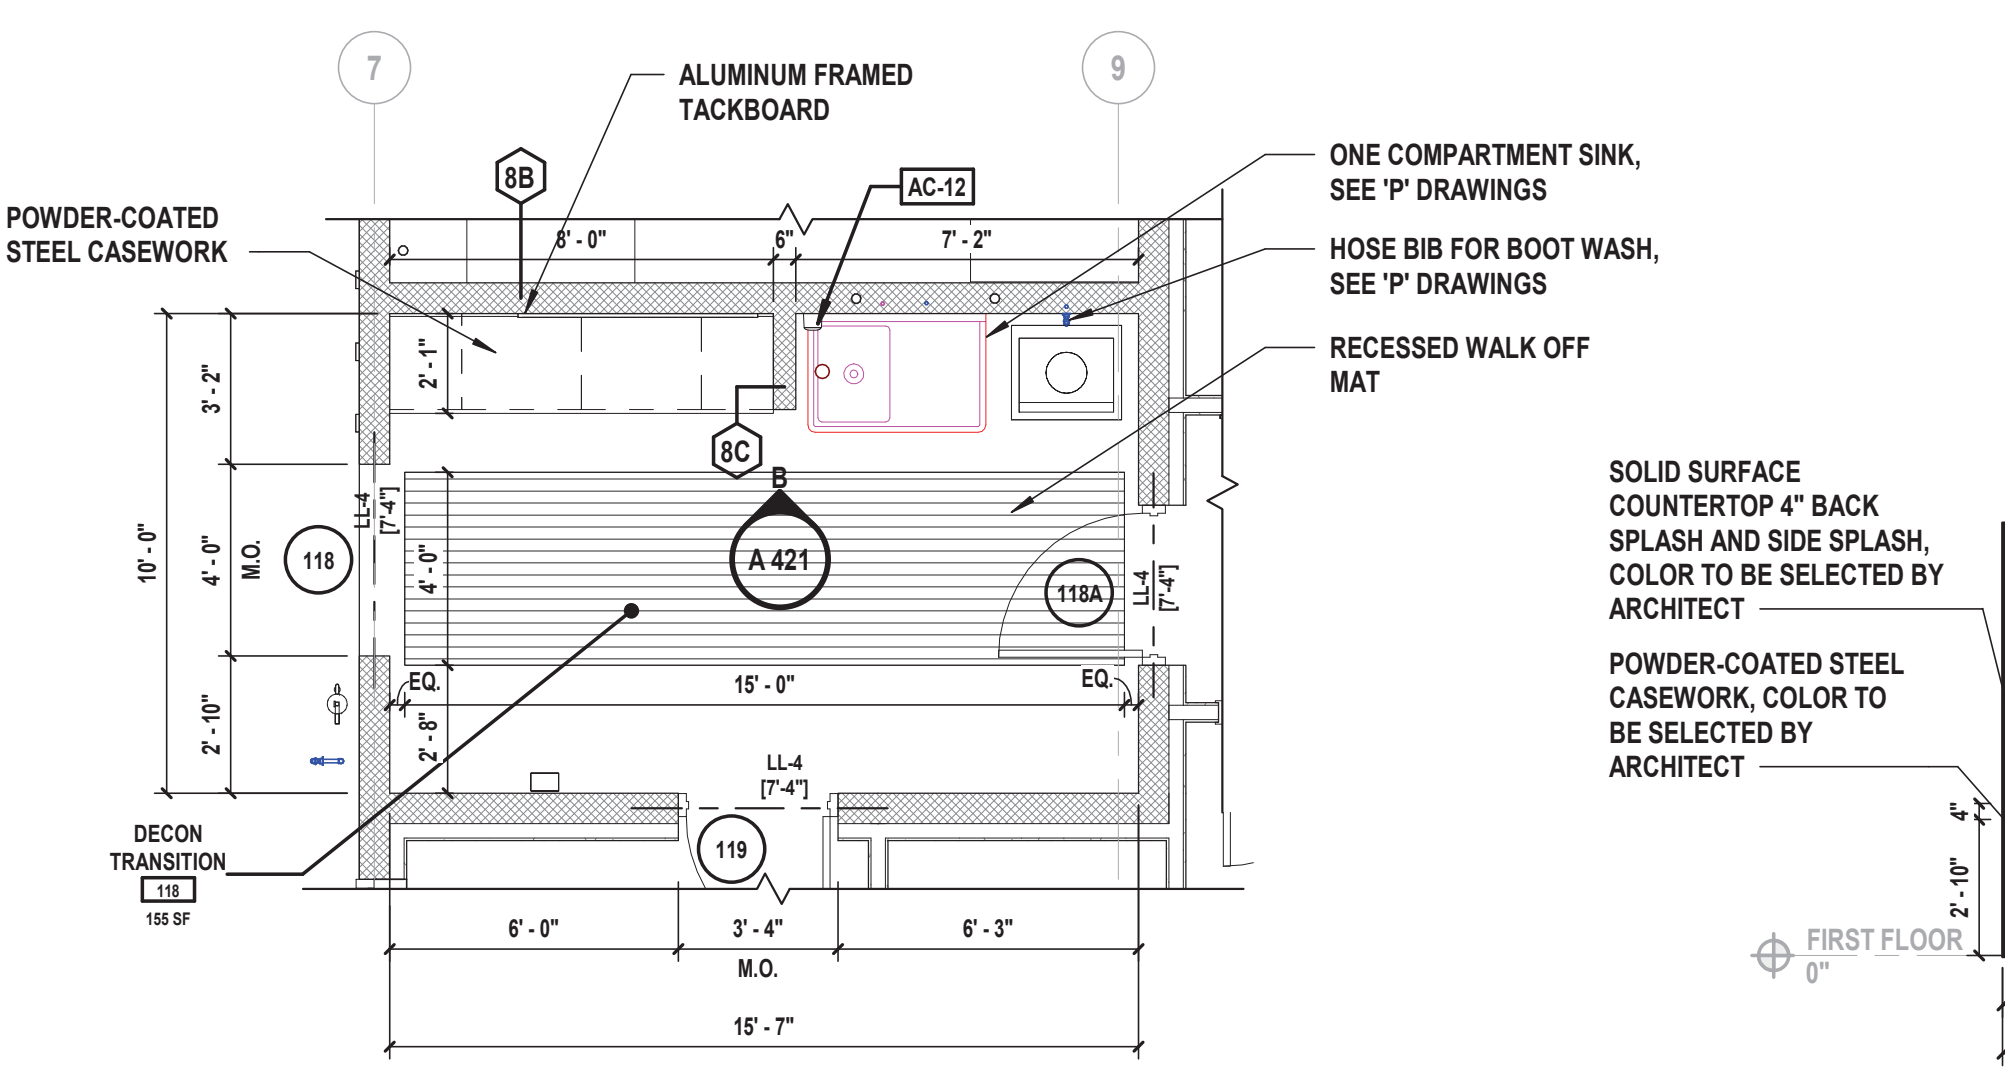


7 Enlarged Decon Transition Plan - 118
SCALE: 1/4" = 1'-0"


B Interior Elevation
SCALE: 1/4" = 1'-0"

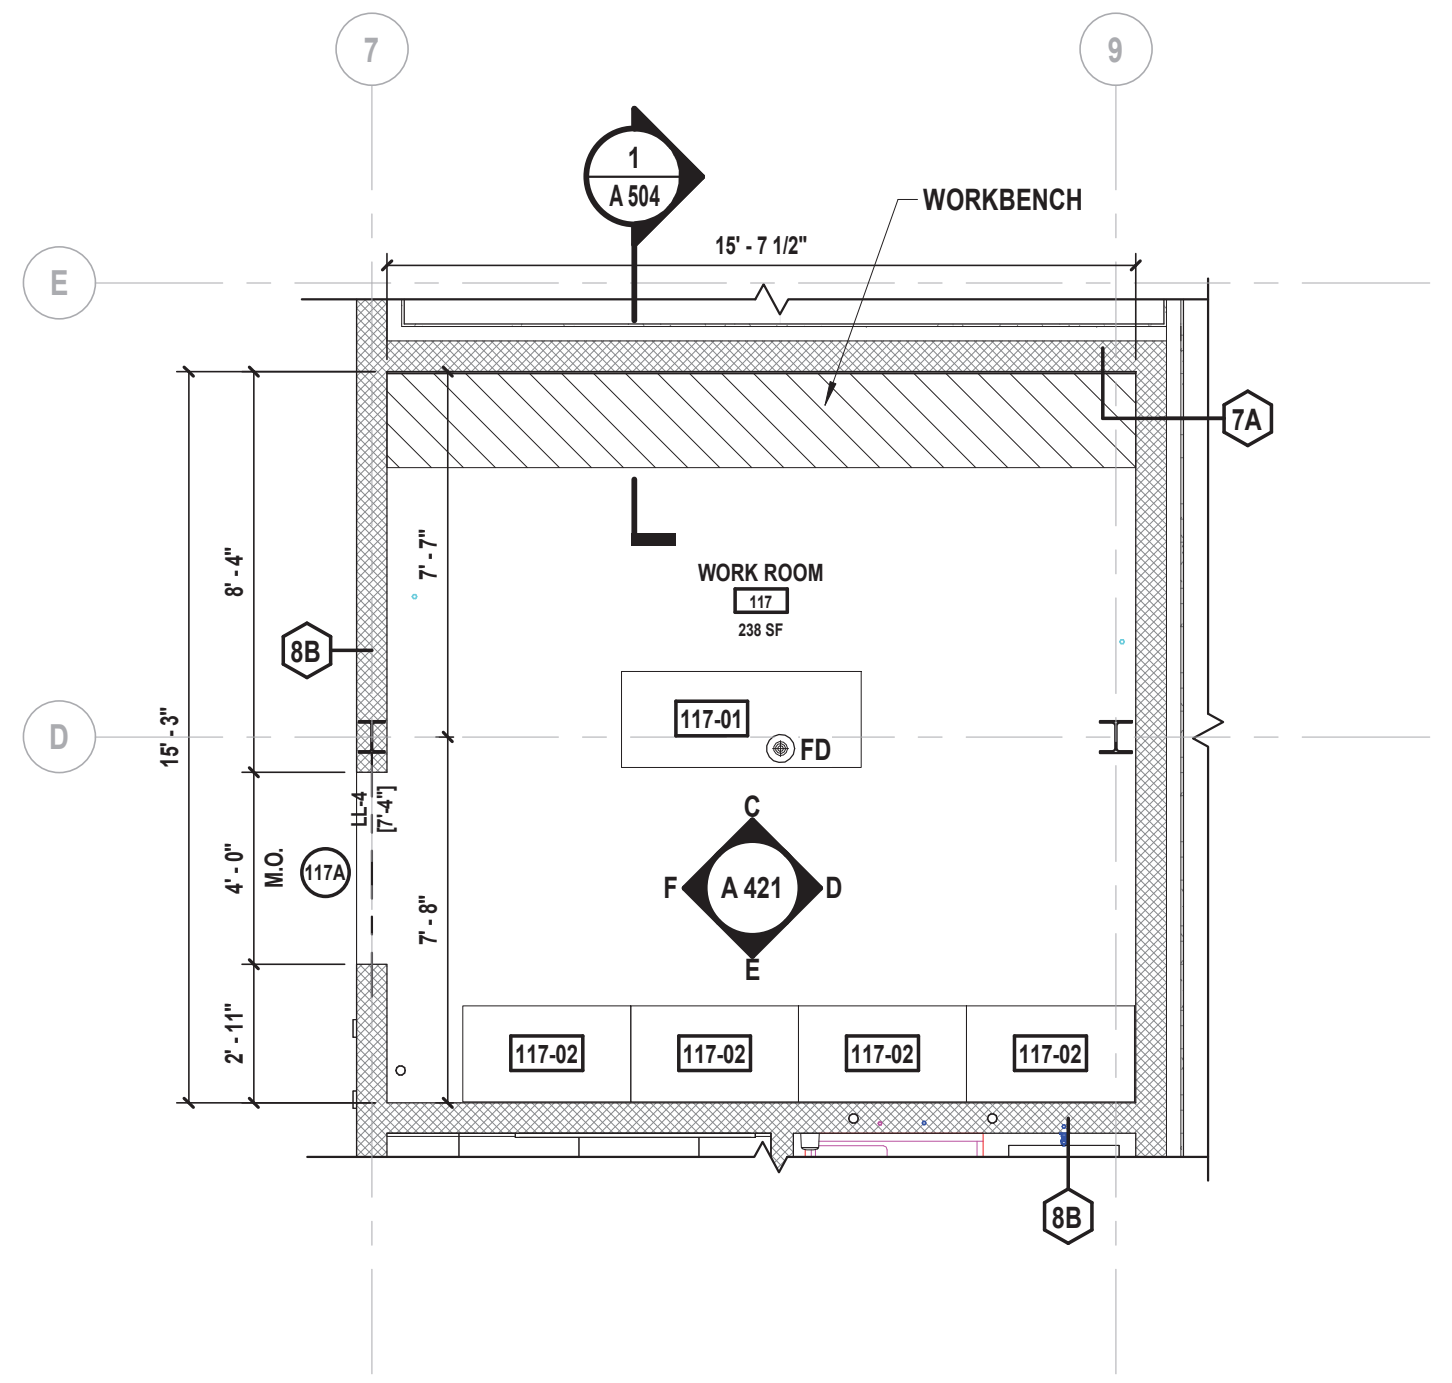


5 Enlarged Work Room Plan
SCALE: 1/4" = 1'-0"

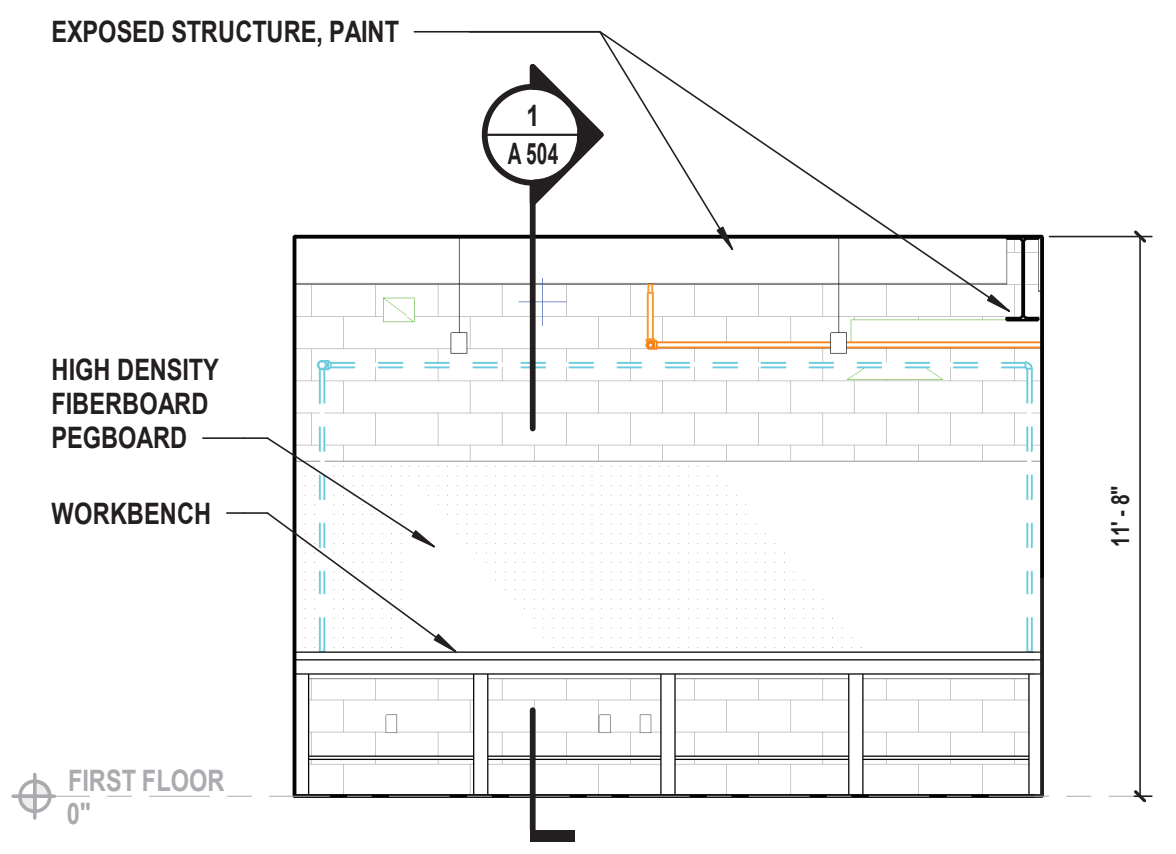


C Interior Elevation
SCALE: 1/4" = 1'-0"

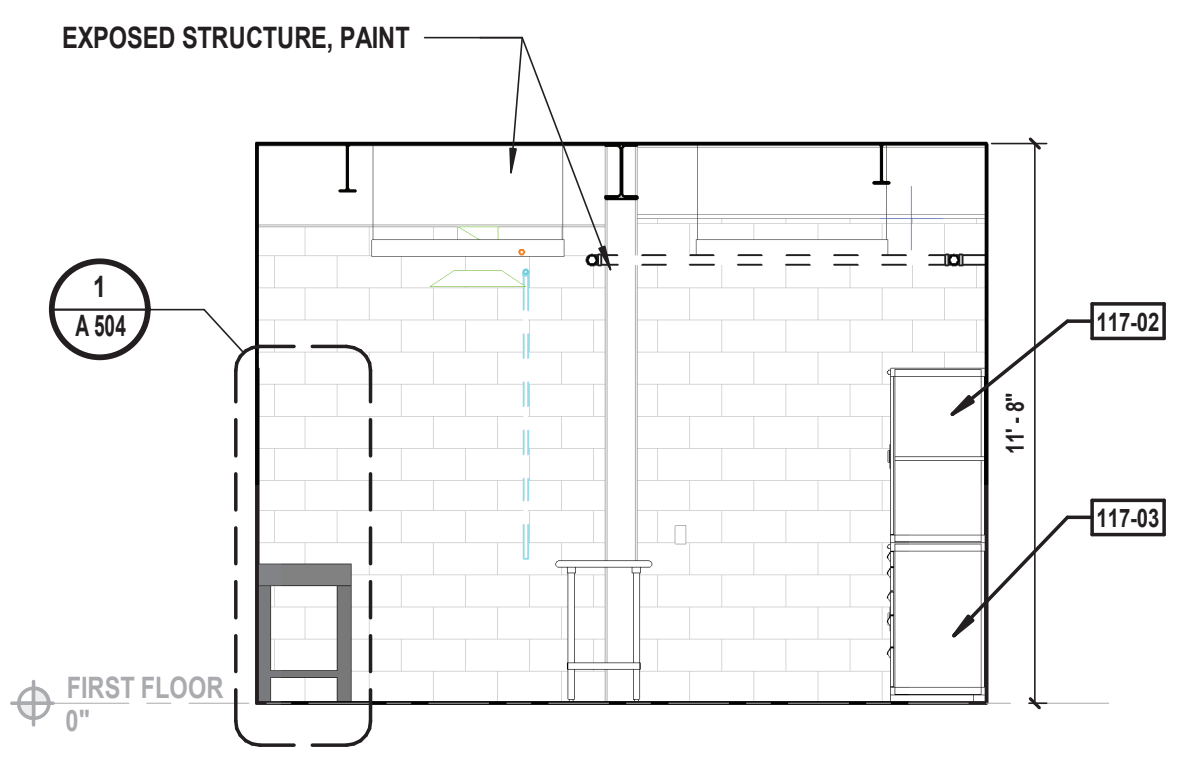


D Interior Elevation
SCALE: 1/4" = 1'-0"

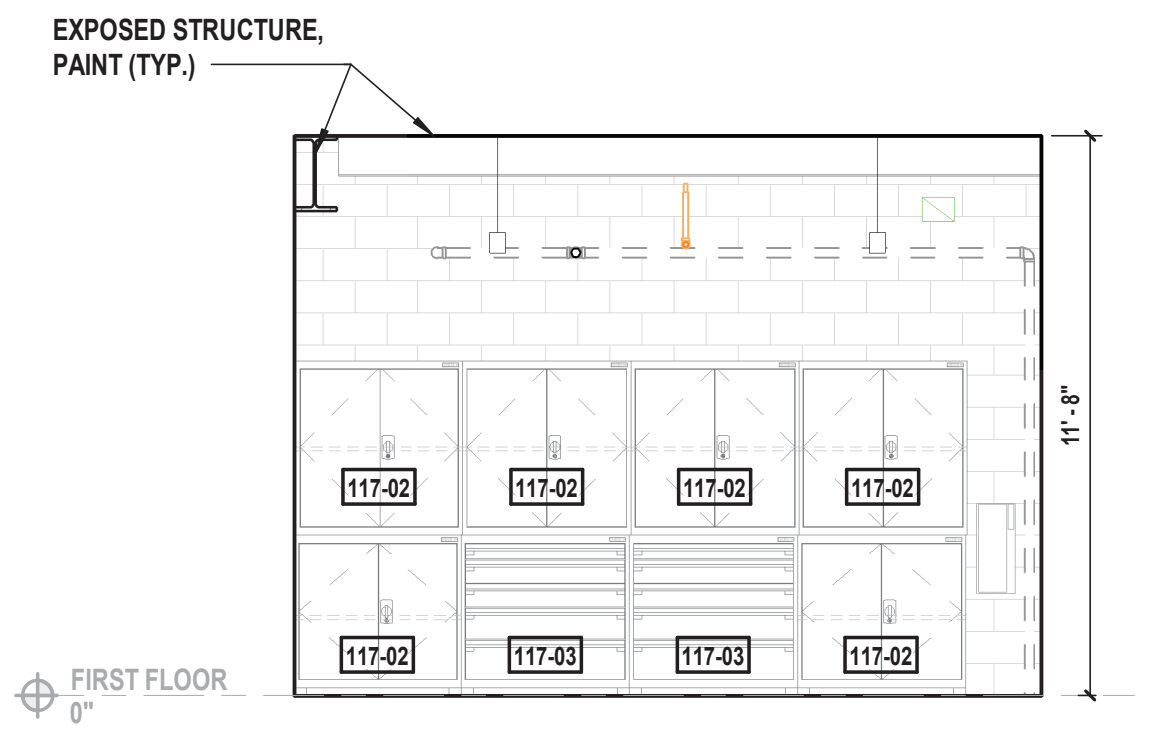

E Interior Elevation
SCALE: 1/4" = 1'-0"

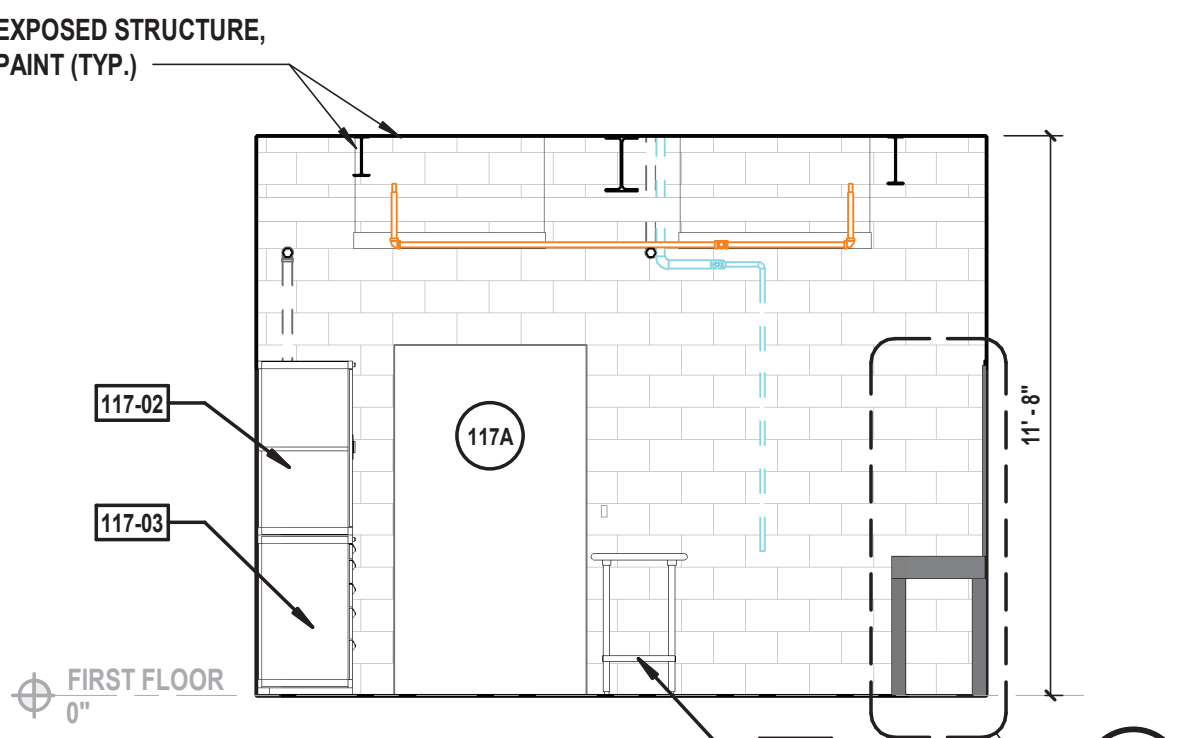

F Interior Elevation
SCALE: 1/4" = 1'-0"

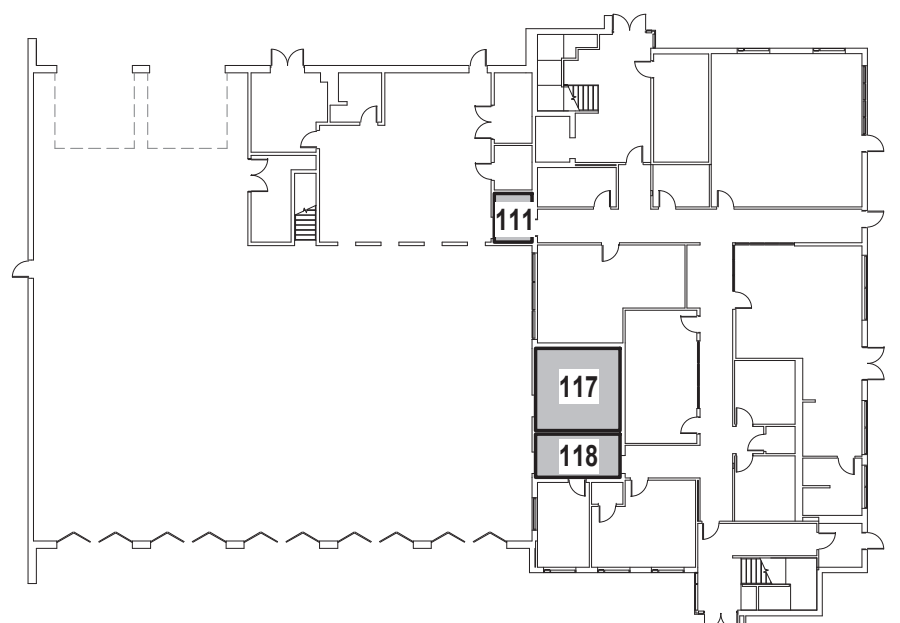

First Floor Key Plan
SCALE: NTS


WORK ROOM EQUIPMENT SCHEDULE - ROOM 117							
MARK	MANUFACTURER	MODEL	DESCRIPTION	LENGTH	DEPTH	HEIGHT	COMMENTS
117-01	ADVANCE TABCO	MS-305	WORK TABLE	2' - 0"	5' - 0"	2' - 11 1/2"	N.I.C. - SHOWN FOR REFERENCE ONLY
117-02	-	-	EXISTING HEAVY DUTY CABINET W/ DOORS	3' - 4"	4' - 0"	3' - 4"	N.I.C. PROVIDED BY OWNER
117-03	-	-	EXISTING HEAVY DUTY CABINET W/ DRAWERS	3' - 4"	4' - 0"	3' - 4"	N.I.C. PROVIDED BY OWNER

1. INSTALL FOOD SERVICE EQUIPMENT LEVEL AND PLUMB, ACCORDING TO MANUFACTURER'S WRITTEN INSTRUCTIONS.
2. CONNECT ALL EQUIPMENT TO UTILITIES AS NEEDED FOR A COMPLETE AND FULLY FUNCTIONAL OPERATION.
3. CONTRACT 'G' IS TO PROVIDE CUT OUTS IN EQUIPMENT AND CABINETRY AS REQUIRED FOR ALL UTILITY CONNECTIONS.
4. PROVIDE CLOSED BUTT AND CONTACT JOINTS THAT DO NOT REQUIRE FILLER, GRIND FIELD WELDS ON STAINLESS STEEL EQUIPMENT UNTIL SMOOTH AND POLISH TO MATCH ADJACENT FINISH.
5. INSTALL EQUIPMENT WITH ACCESS AND MAINTENANCE CLEARANCES THAT COMPLY WITH MANUFACTURER'S WRITTEN INSTALLATION INSTRUCTIONS.
6. INSTALL SEALANT IN JOINTS BETWEEN EQUIPMENT AND ABUTTING SURFACES WITH CONTINUOUS JOINT BACKING, UNLESS OTHER WISE INDICATED. PROVIDE AIRTIGHT, WATERTIGHT, VERMIN-PROOF SANITARY JOINTS.
7. AFTER EQUIPMENT INSTALL IS COMPLETE, REPAIR DAMAGED FINISHES.
8. CLEAN AND ADJUST EQUIPMENT AS REQUIRED TO PRODUCE READY-FOR-USE CONDITION.
9. PROTECT EQUIPMENT FROM DAMAGE DURING REMAINDER OF THE CONSTRUCTION PERIOD.
10. ENGAGE A FACTORY AUTHORIZED SERVICE REPRESENTATIVE TO TRAIN OWNER'S MAINTENANCE PERSONNEL TO ADJUST, OPERATE AND MAINTAIN FOOD SERVICE EQUIPMENT.
11. CONTRACT 'G' TO PROVIDE ALL REQUIRED ACCESSORIES FOR A COMPLETE AND READY-FOR-USE INSTALLATION.

[illegible]



First Floor Key Plan

SCALE: NTS

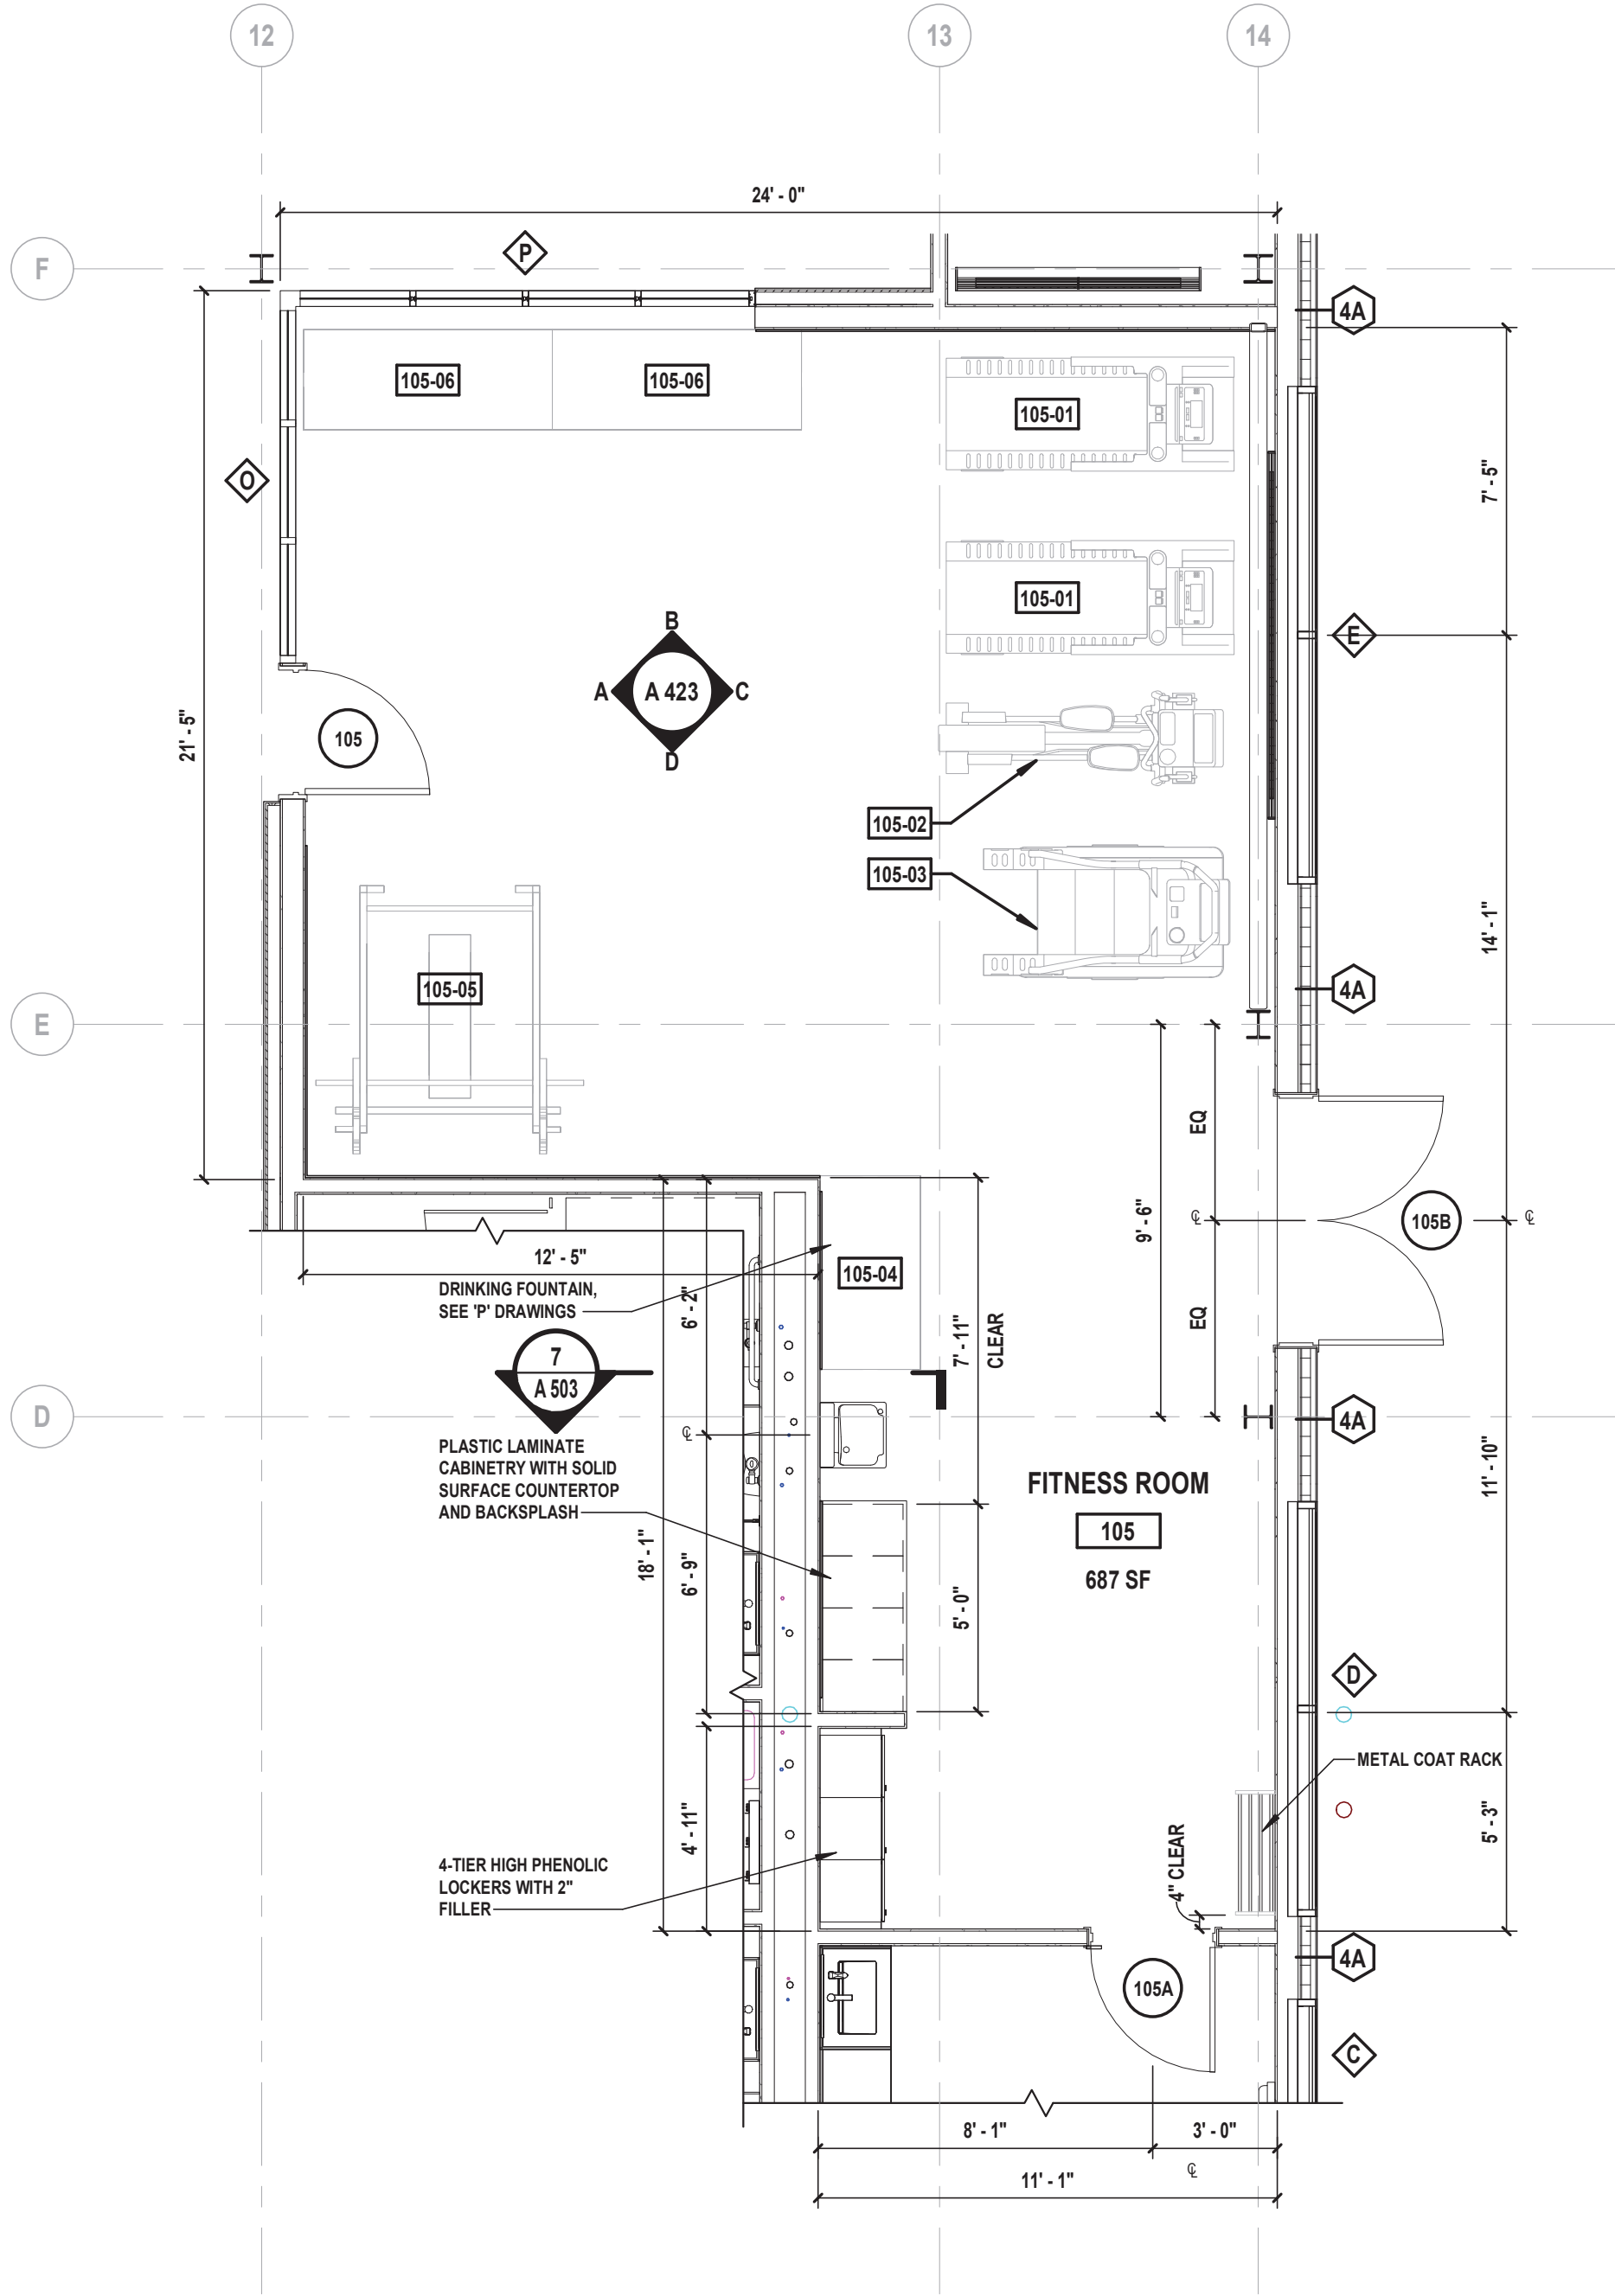


1 Enlarged Fitness Room Plan
SCALE: 1/4" = 1'-0"


FITNESS ROOM EQUIPMENT SCHEDULE - ROOM 105		
MARK	DESCRIPTION	COMMENTS
105-01	TREADMILL	N.I.C. - SHOWN FOR REFERENCE ONLY
105-02	ELLIPTICAL	N.I.C. - SHOWN FOR REFERENCE ONLY
105-03	STAIR MASTER	N.I.C. - SHOWN FOR REFERENCE ONLY
105-04	WEIGHT RACK	N.I.C. - SHOWN FOR REFERENCE ONLY
105-05	POWER RACK AND BENCH	N.I.C. - SHOWN FOR REFERENCE ONLY
105-06	WEIGHT RACK	N.I.C. - SHOWN FOR REFERENCE ONLY

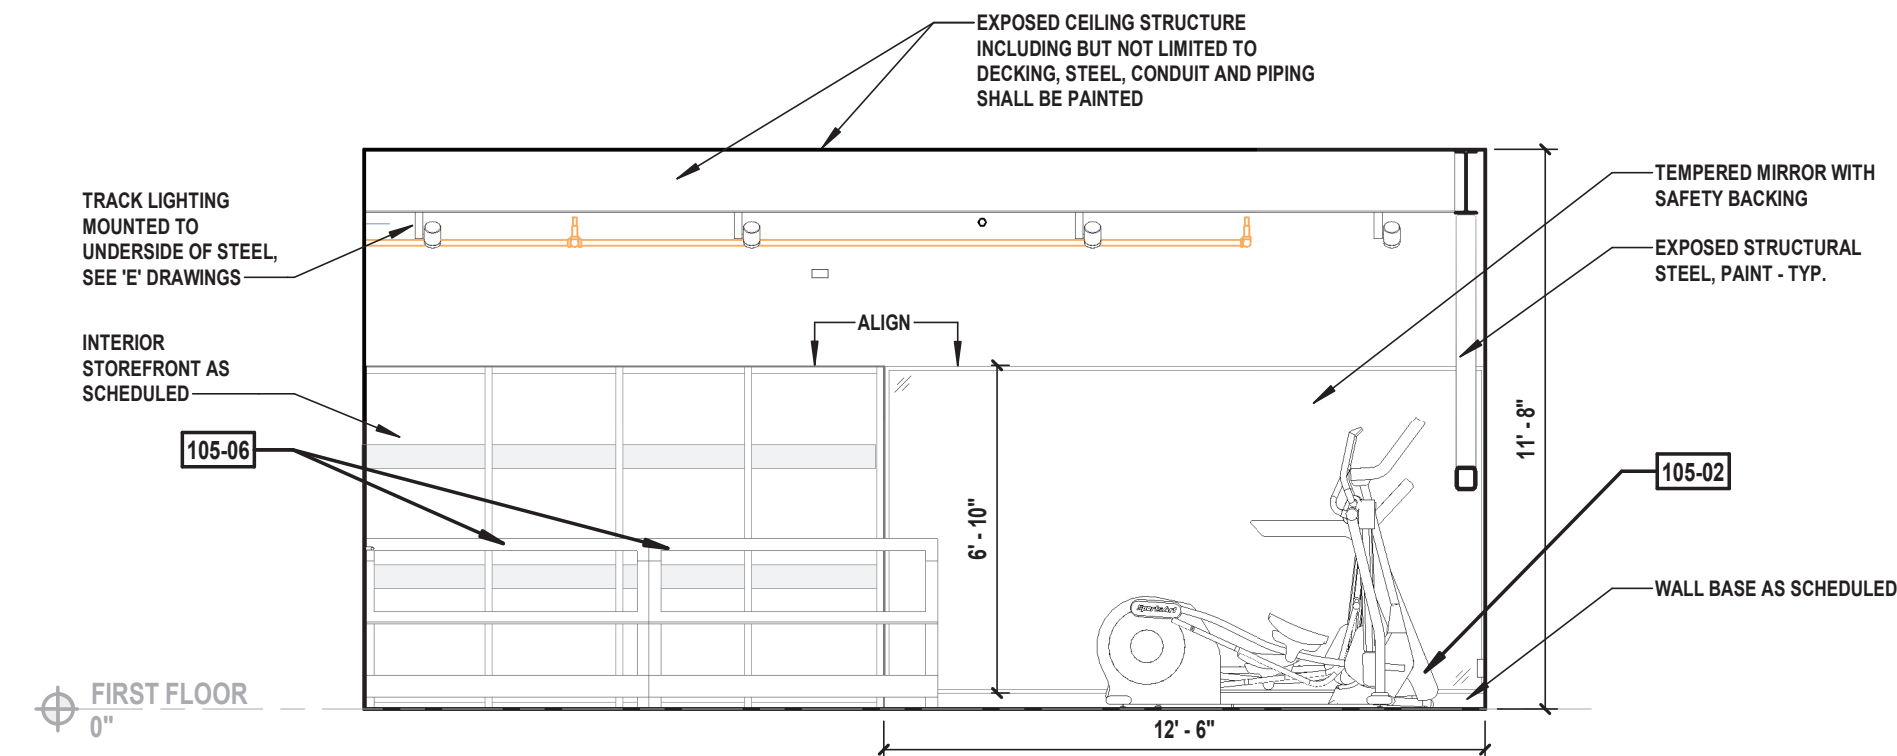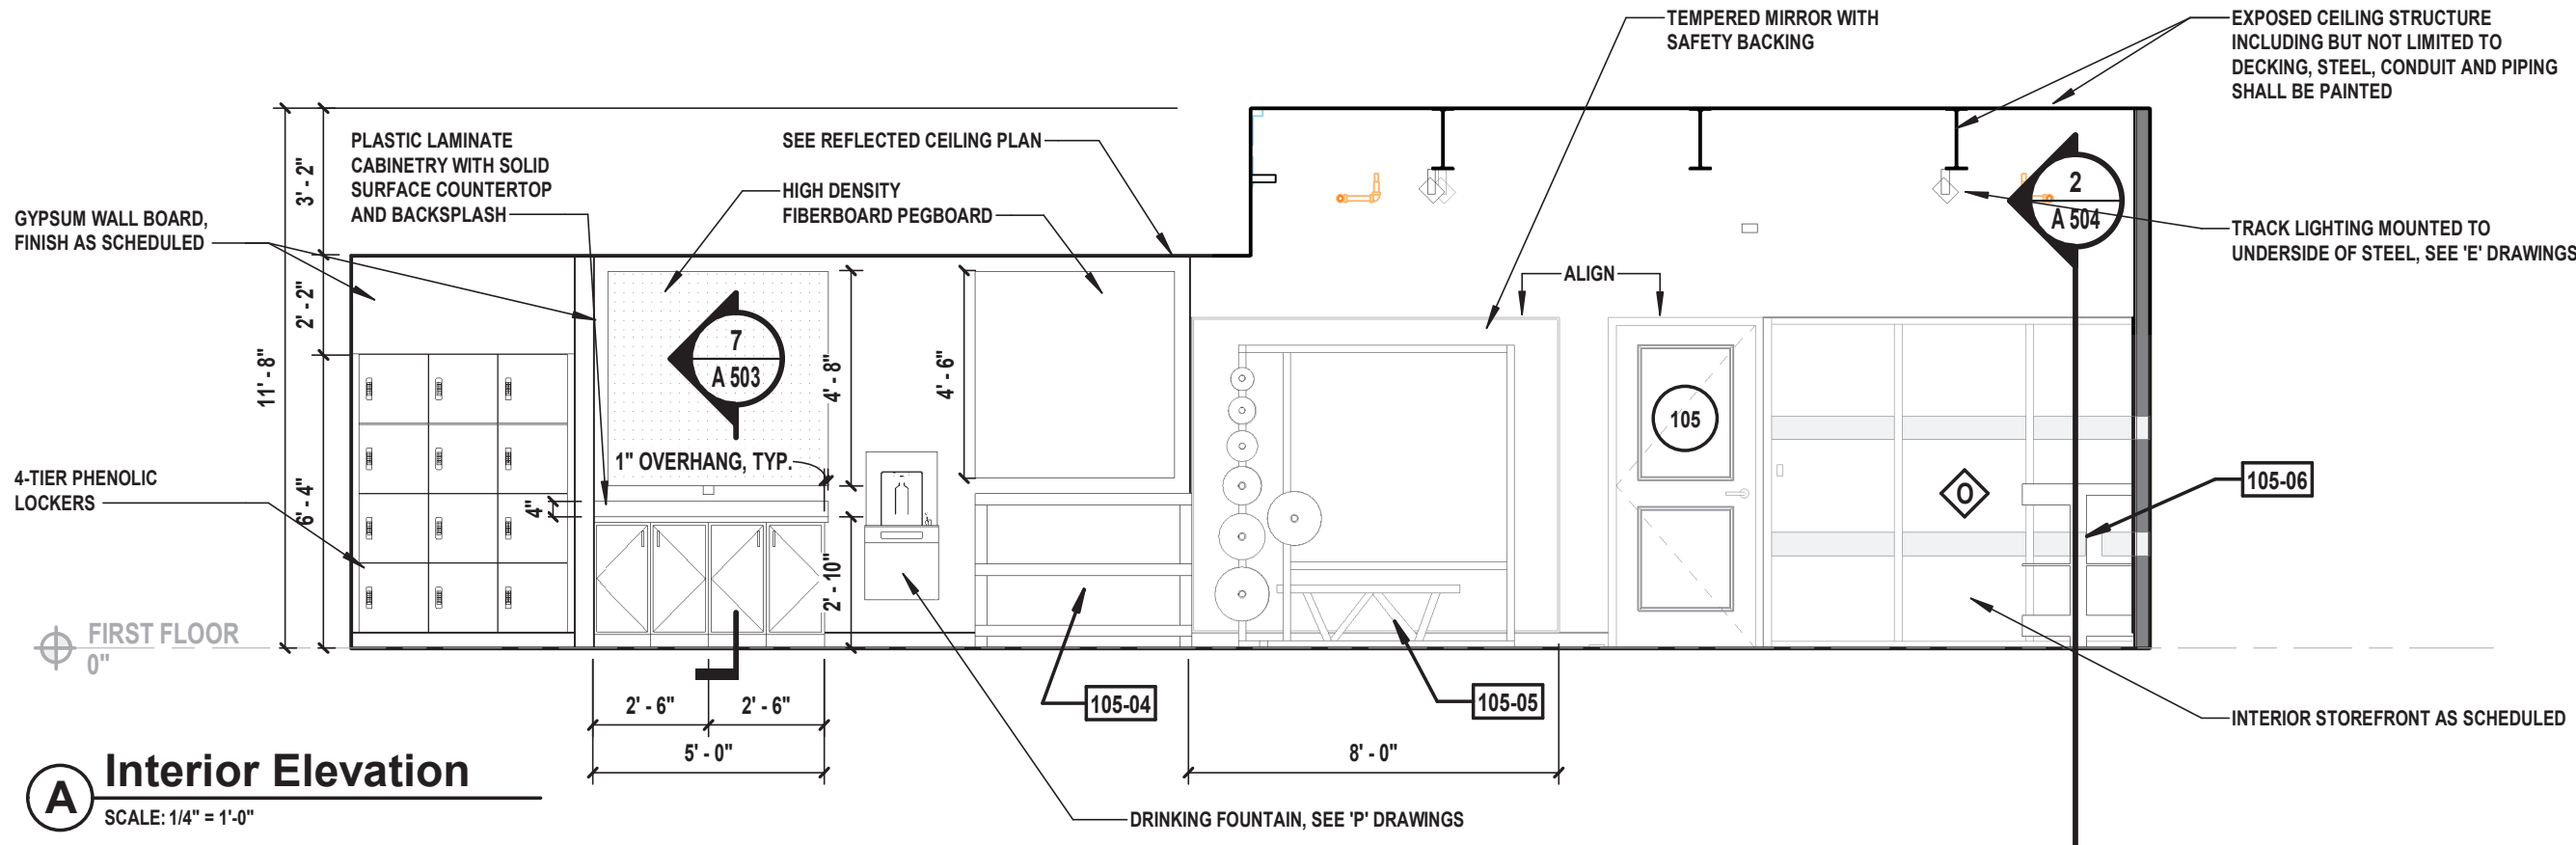


B Interior Elevation
SCALE: 1/4" = 1'-0"

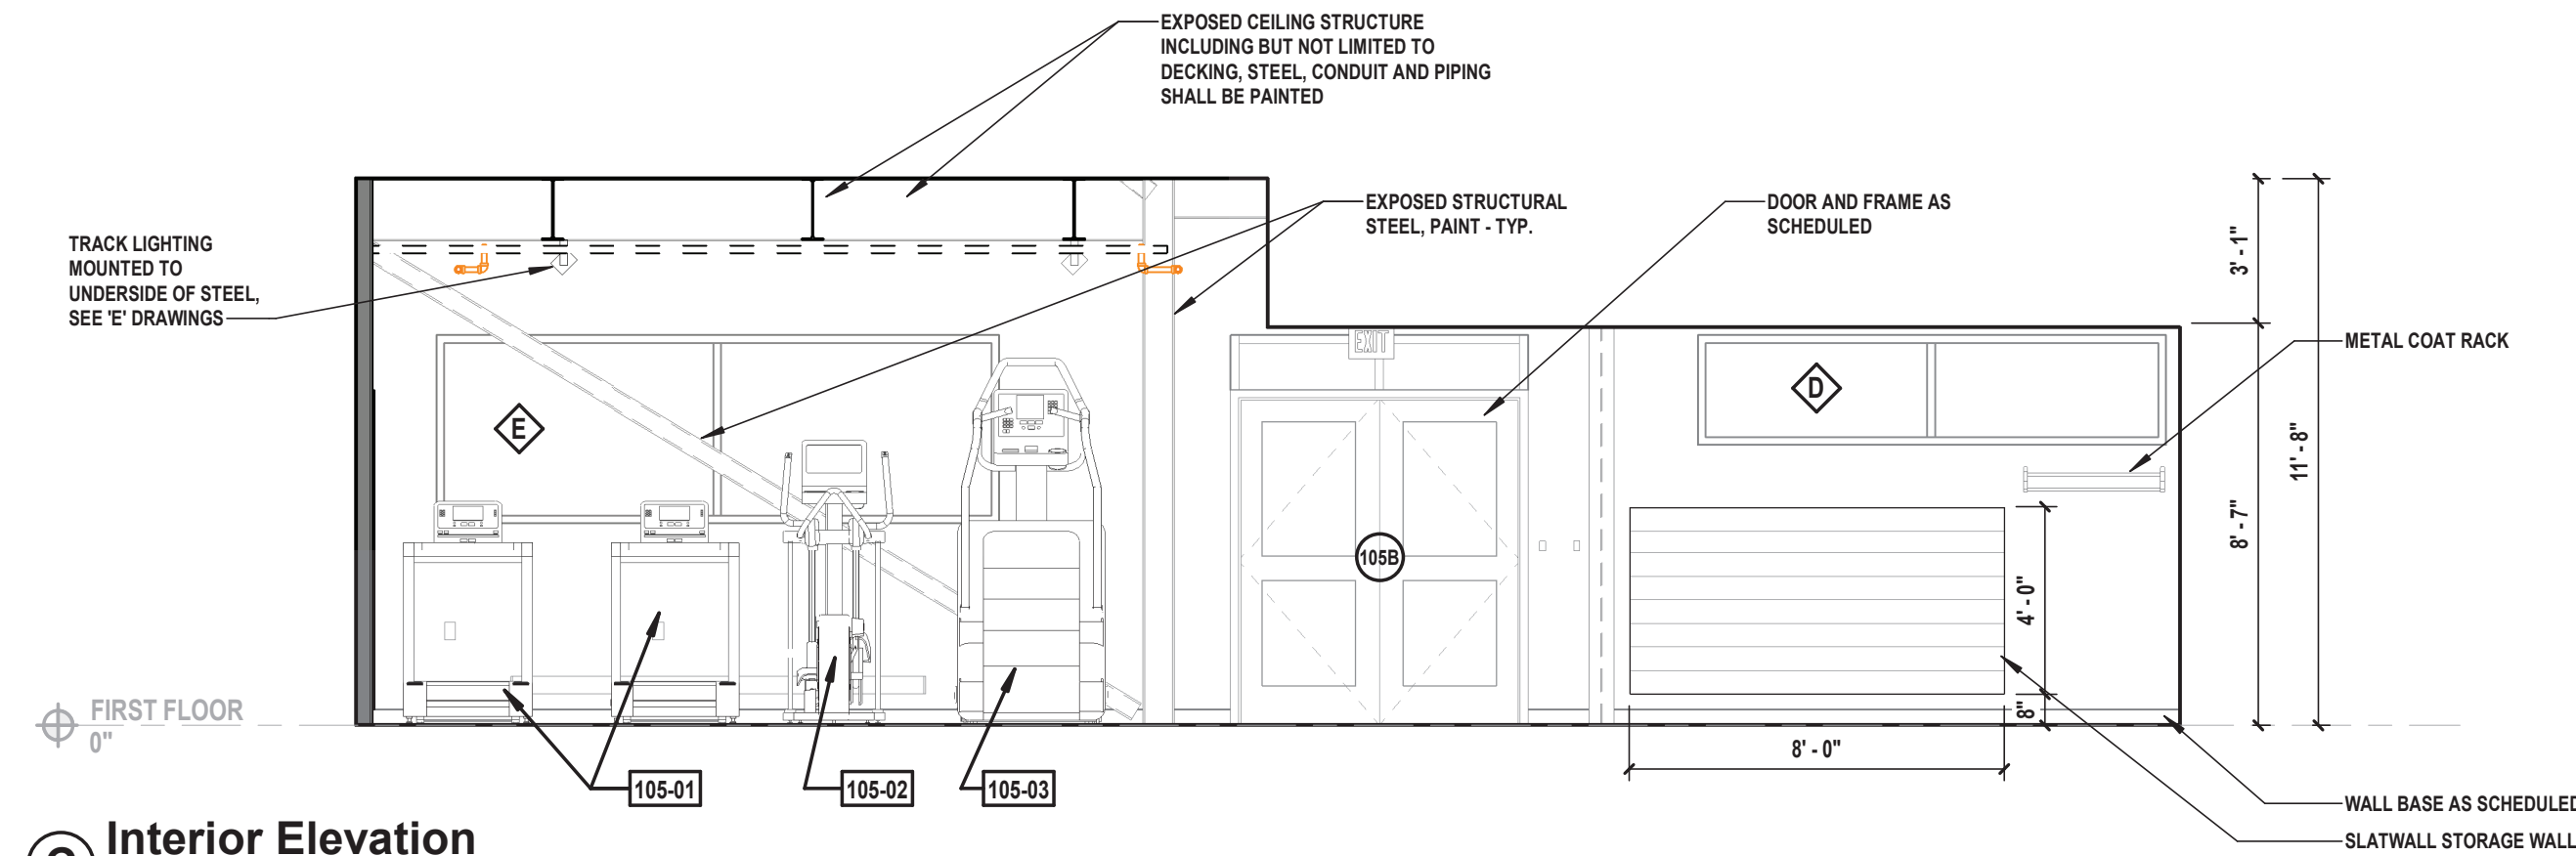

C Interior Elevation
SCALE: 1/4" = 1'-0"

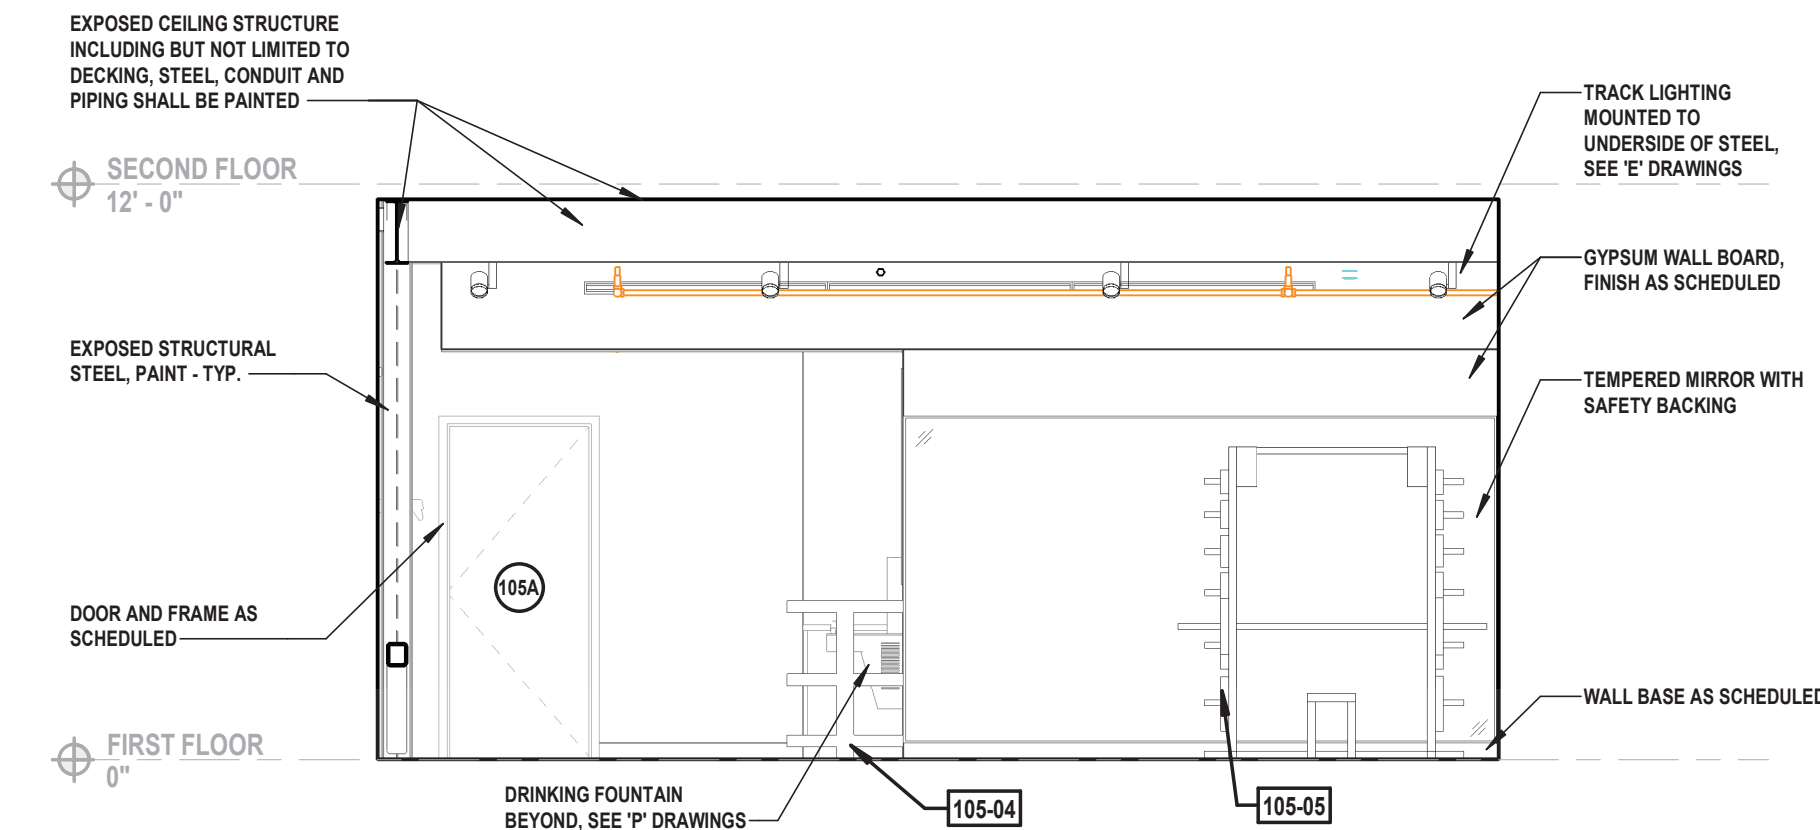

D Interior Elevation
SCALE: 1/4" = 1'-0"

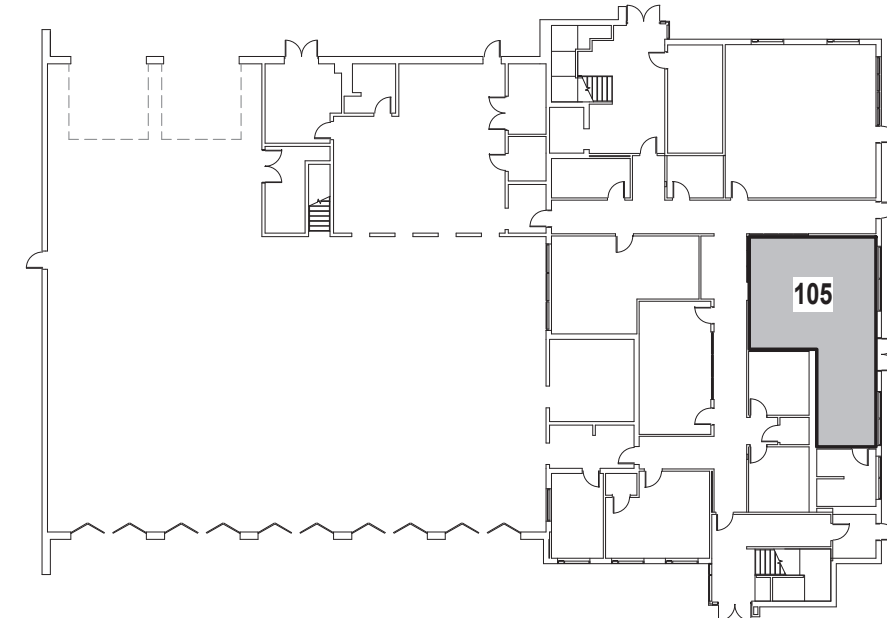

First Floor Key Plan
SCALE: NTS

MARK	DATE	DESCRIPTION

REGISTERED ARCHITECT
PATRICK O. STONE
STATE OF NEW YORK
029654
10/31/2025
PATRICK O. STONE, R.A.
NY PROFESSIONAL ARCHITECT LIC. NO. 039654
*IN ACCORDANCE WITH ARTICLE 145, SECTION 1209 OF THE NYS EDUCATION LAW,
ALTERNATION OF THIS DOCUMENT EXCEPT BY A LICENSED PROFESSIONAL IS ILLEGAL.*
DESIGNED BY: DBS/RLG DRAWN BY: KAP CHECKED BY: DBS REVIEWED BY: POS
PROJECT No: TRFD 2302 DATE: FEBRUARY 2025 SCALE: AS SHOWN

CLIENT
**THIELLS
ROSEVILLE FIRE
DISTRICT**

NEW 26-100 FIRE
HEADQUARTERS


65 W RAMAPO ROAD
GARNERVILLE, NY 10923

CONTRACT
**CONTRACT G
GENERAL CONSTRUCTION**

STATUS
FINAL BID DOCUMENT

SHEET TITLE
**ENLARGED FITNESS ROOM PLANS
& INTERIOR ELEVATIONS**


DRAWING No.
A 423.00

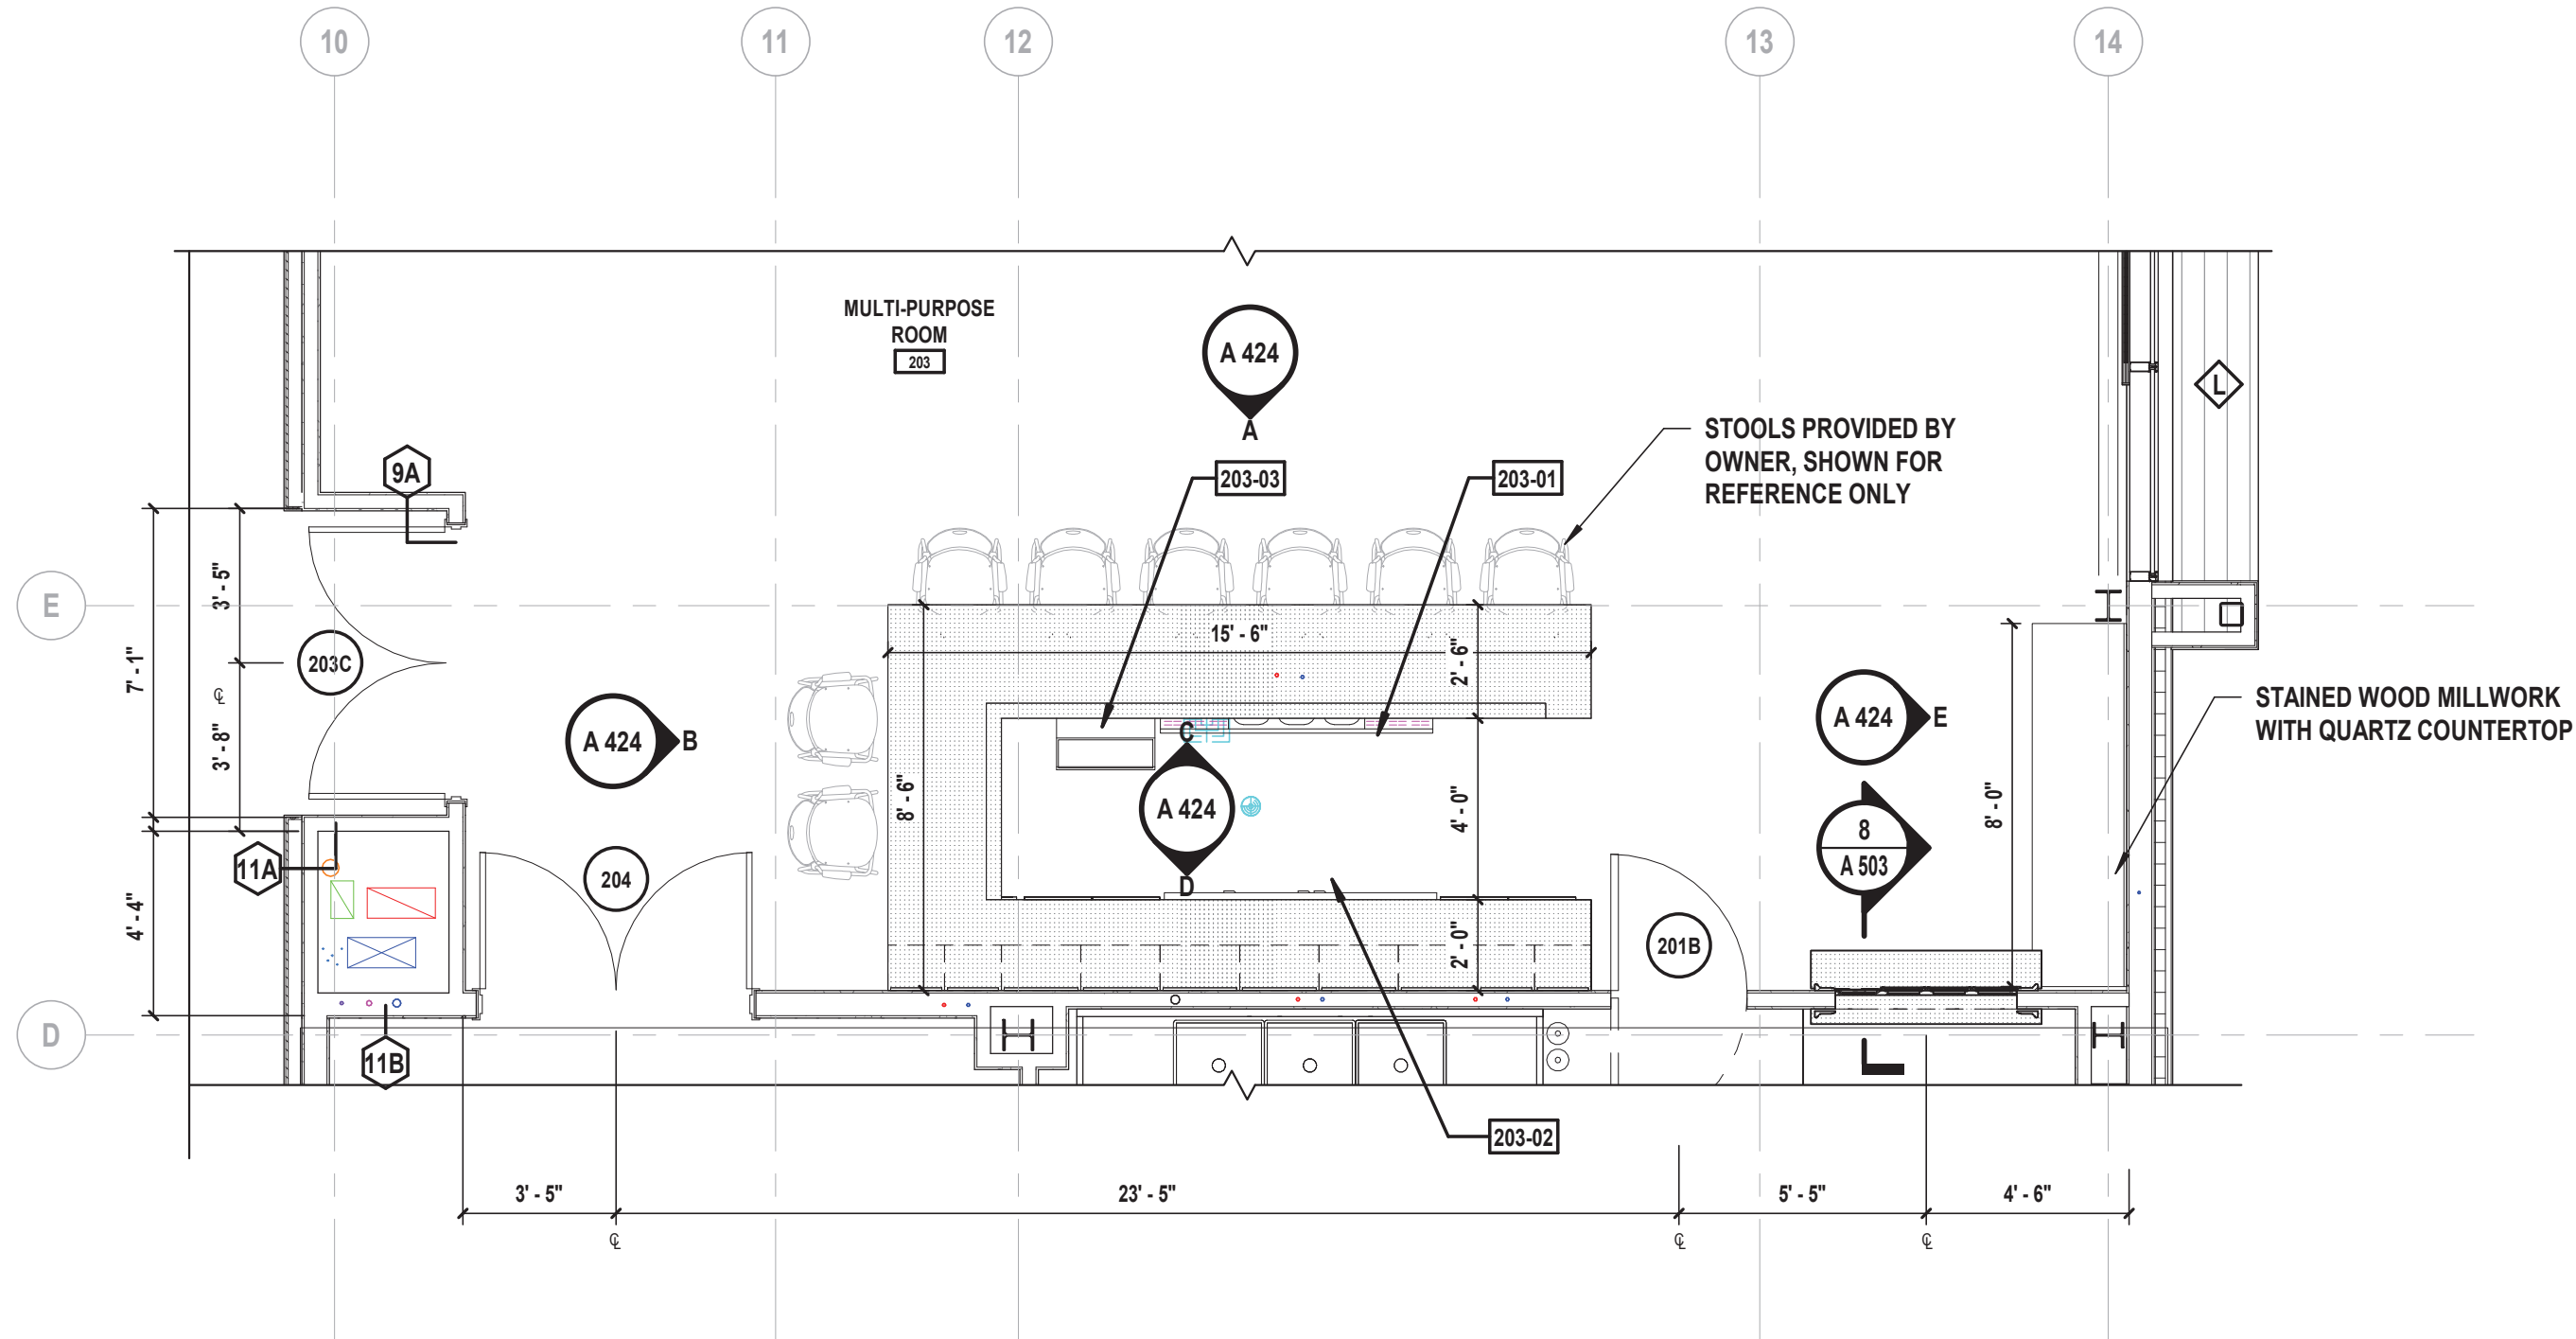


1 Enlarged Multi-Purpose Room Service Area
SCALE: 1/4" = 1'-0"

EQUIPMENT SCHEDULE - MULTI-PURPOSE ROOM 203

MARK	MANUFACTURER	MODEL	DESCRIPTION	COMMENTS
203-01	KROWNE METAL	KR19-63C	THREE COMPARTMENT BAR SINK	N.I.C. PROVIDED BY OWNER, CONNECTIONS BY CONTRACT P
203-02	TRUE	TBB24-72-3G-Z1-BST-B-1	BACKBAR COOLER	N.I.C. PROVIDED BY OWNER
203-03	MANITOWOC ICE	UDF0140A	UNDERCOUNTER ICE MAKER	N.I.C. PROVIDED BY OWNER, CONNECTIONS BY CONTRACT P

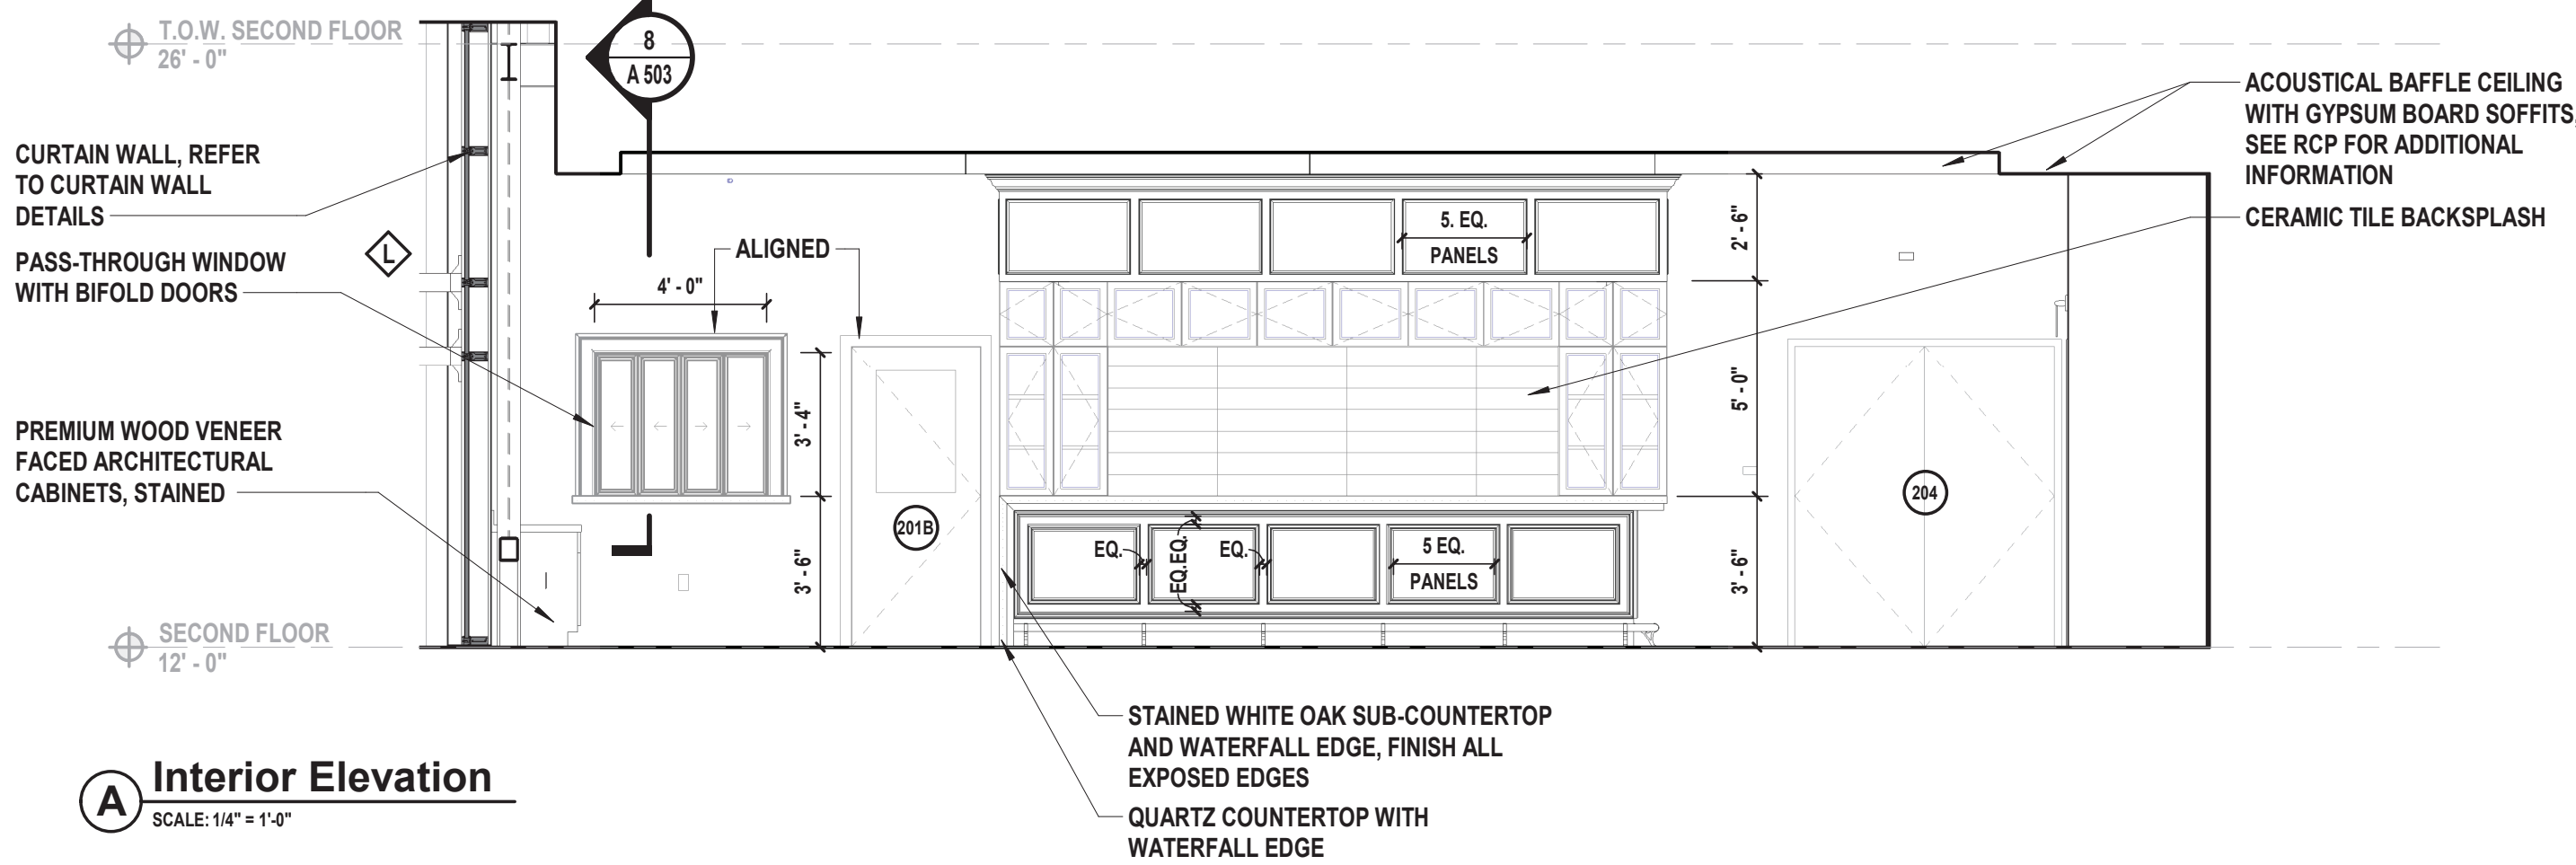


A Interior Elevation
SCALE: 1/4" = 1'-0"

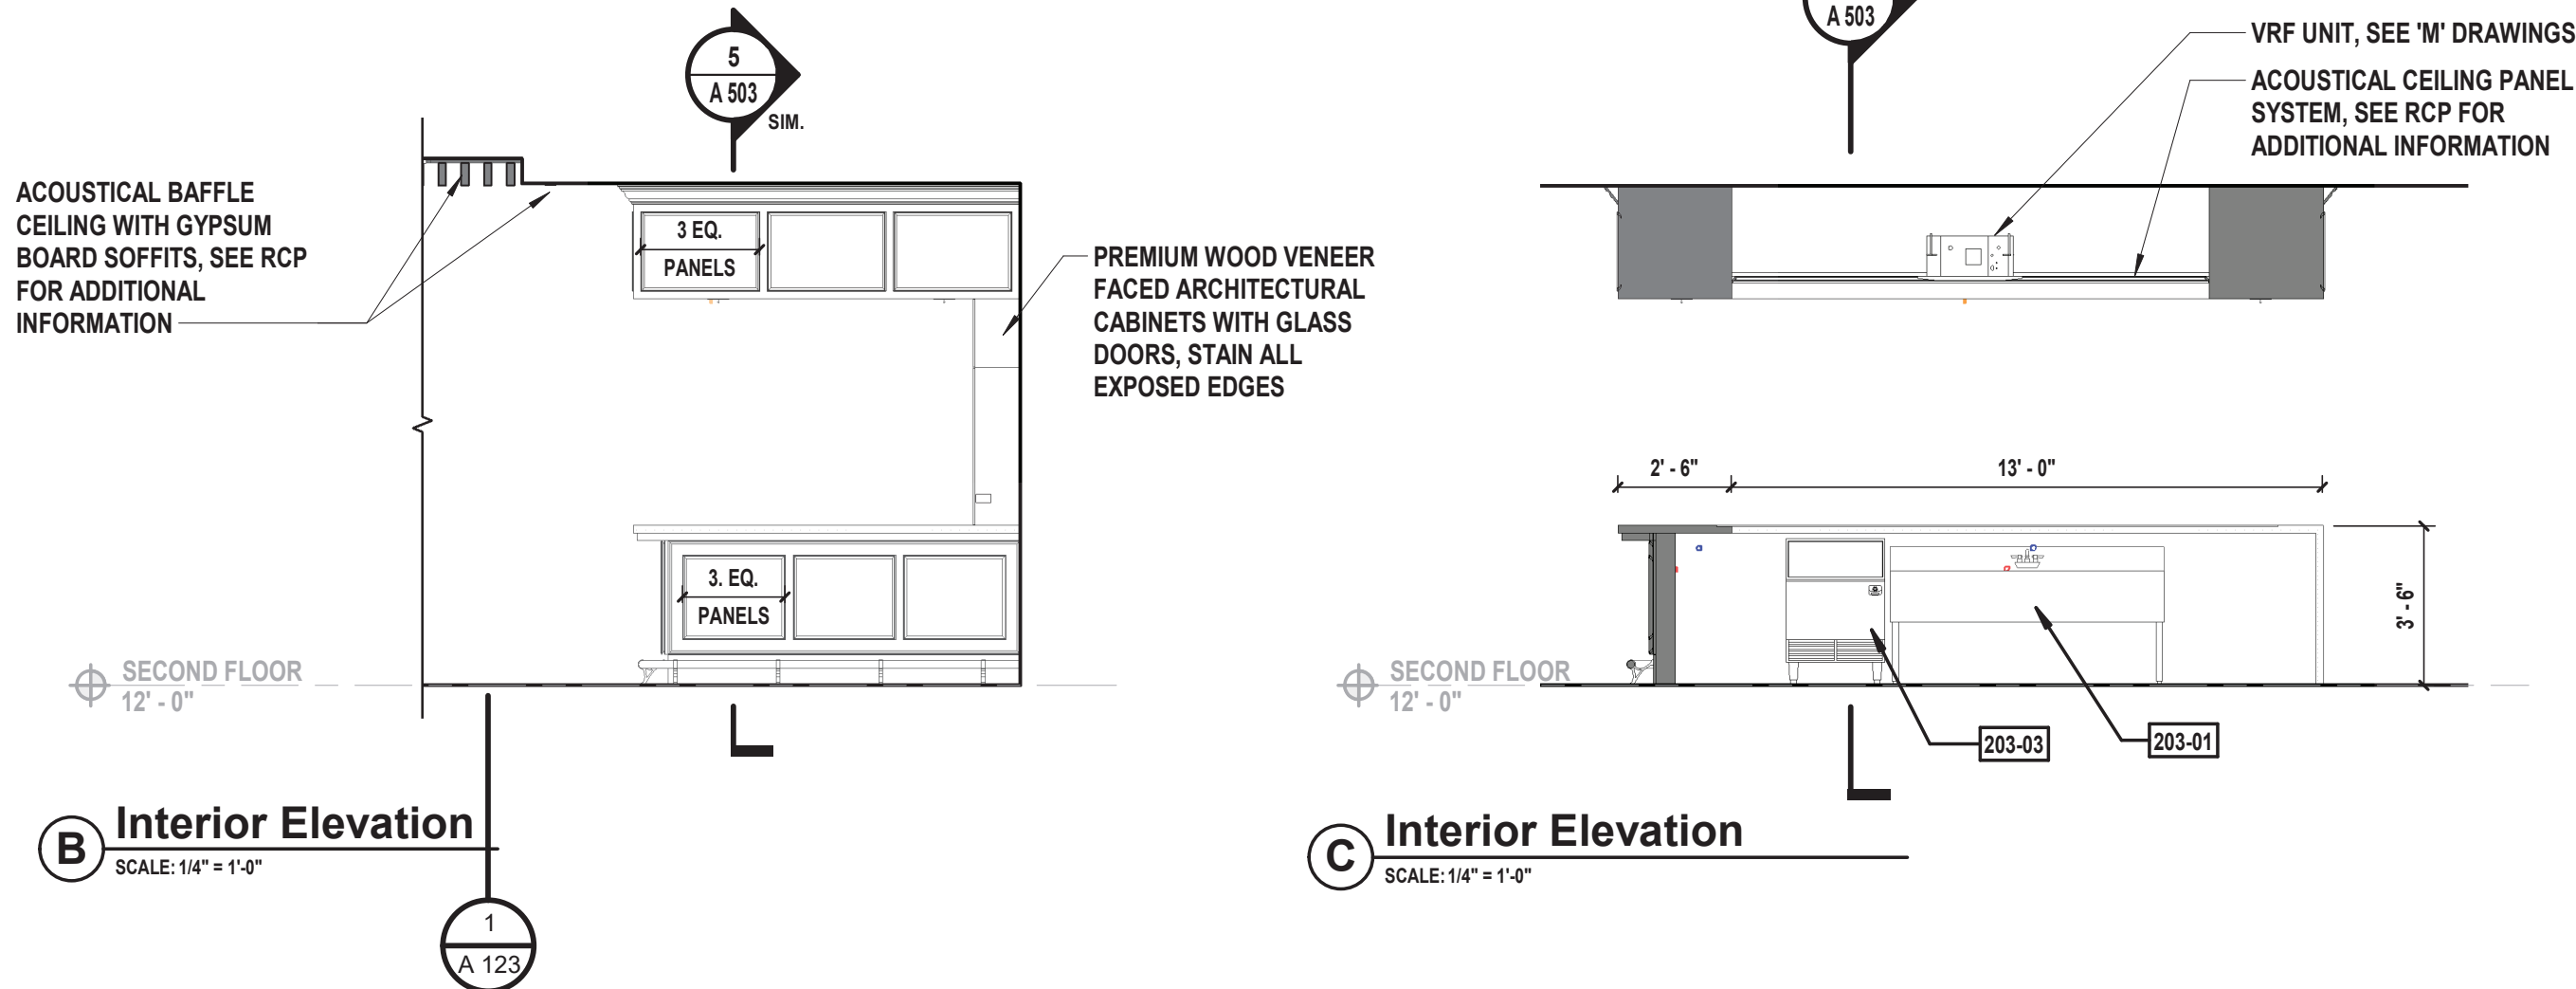


B Interior Elevation
SCALE: 1/4" = 1'-0"


C Interior Elevation
SCALE: 1/4" = 1'-0"

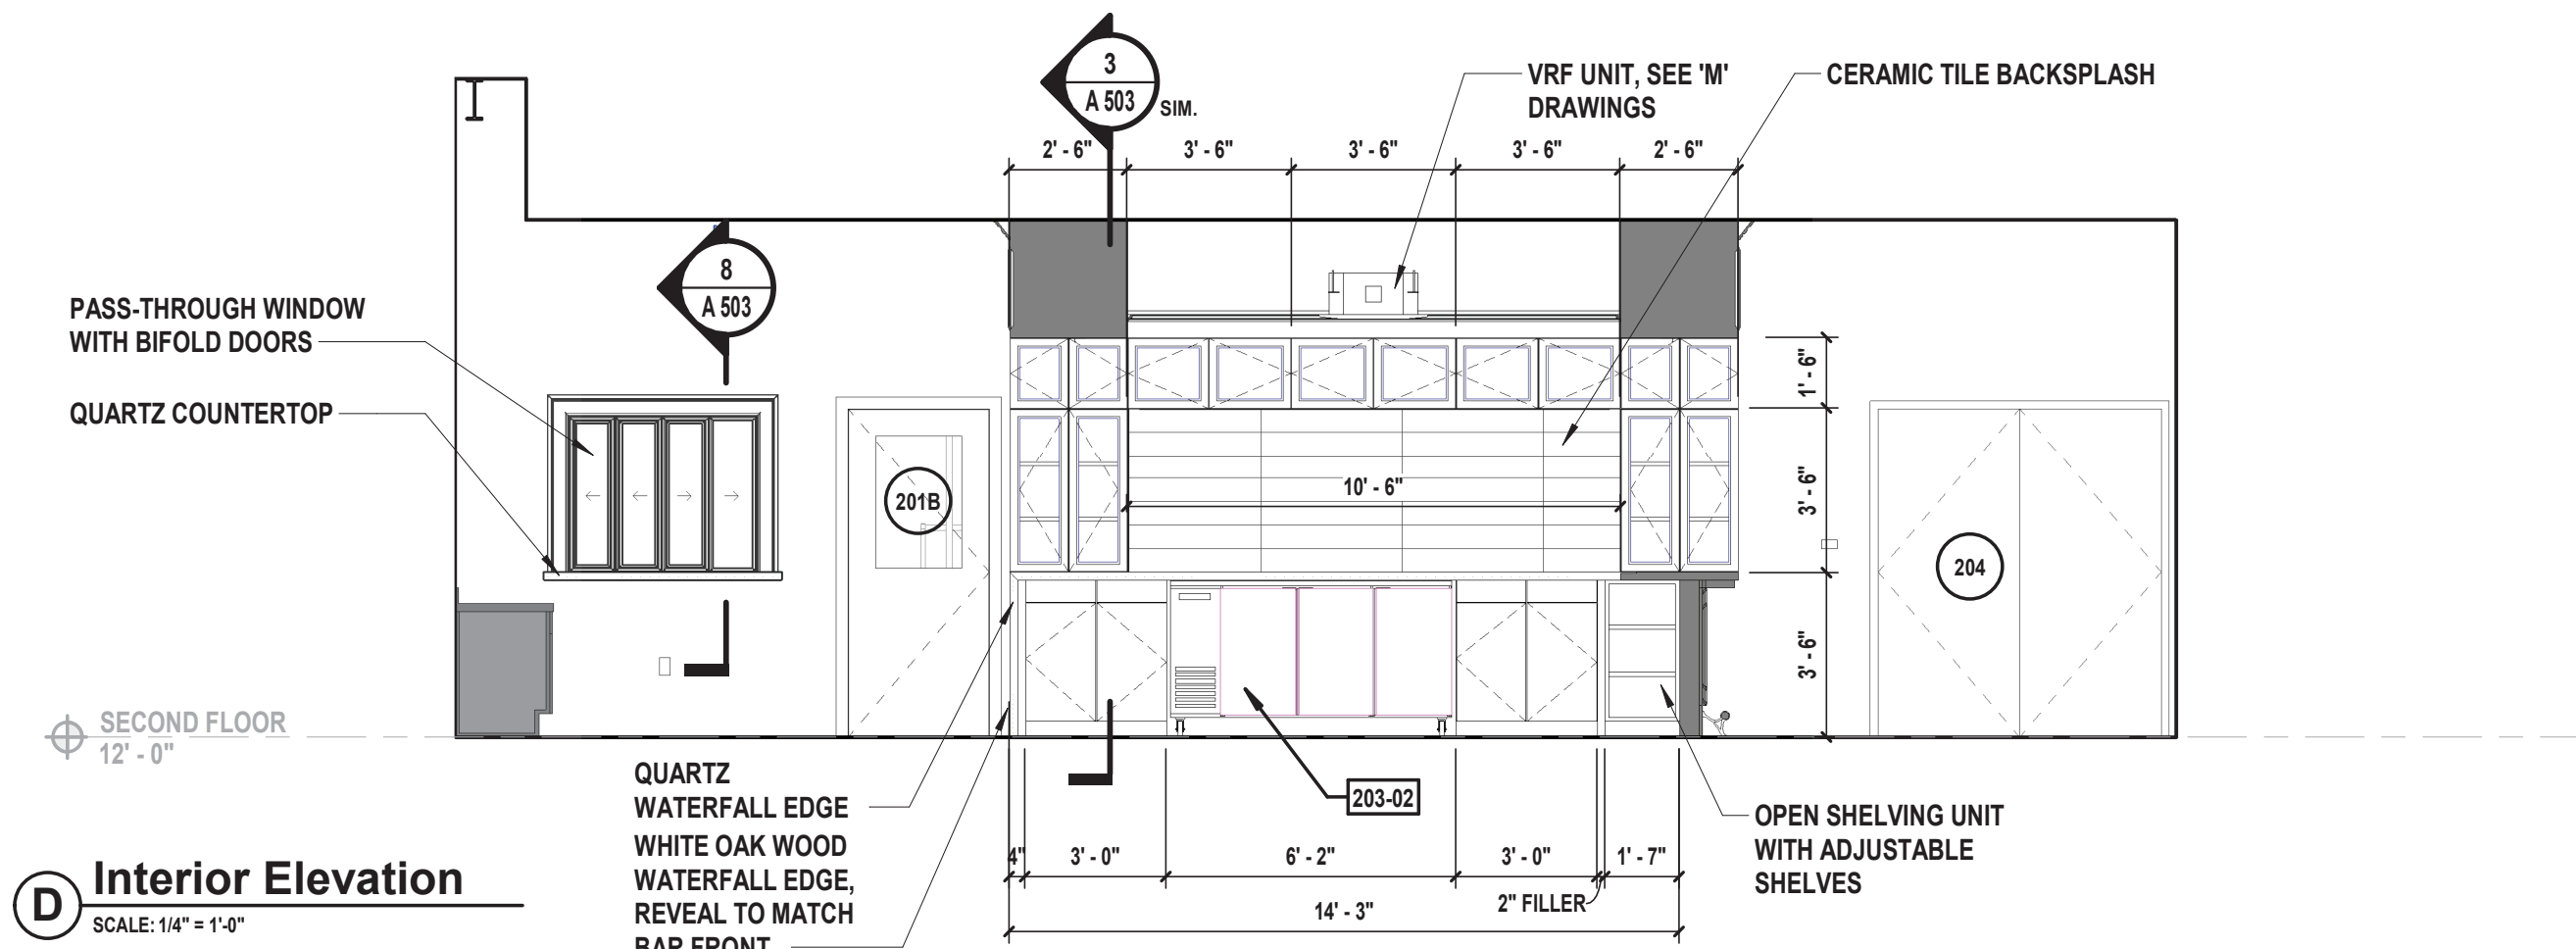

D Interior Elevation
SCALE: 1/4" = 1'-0"

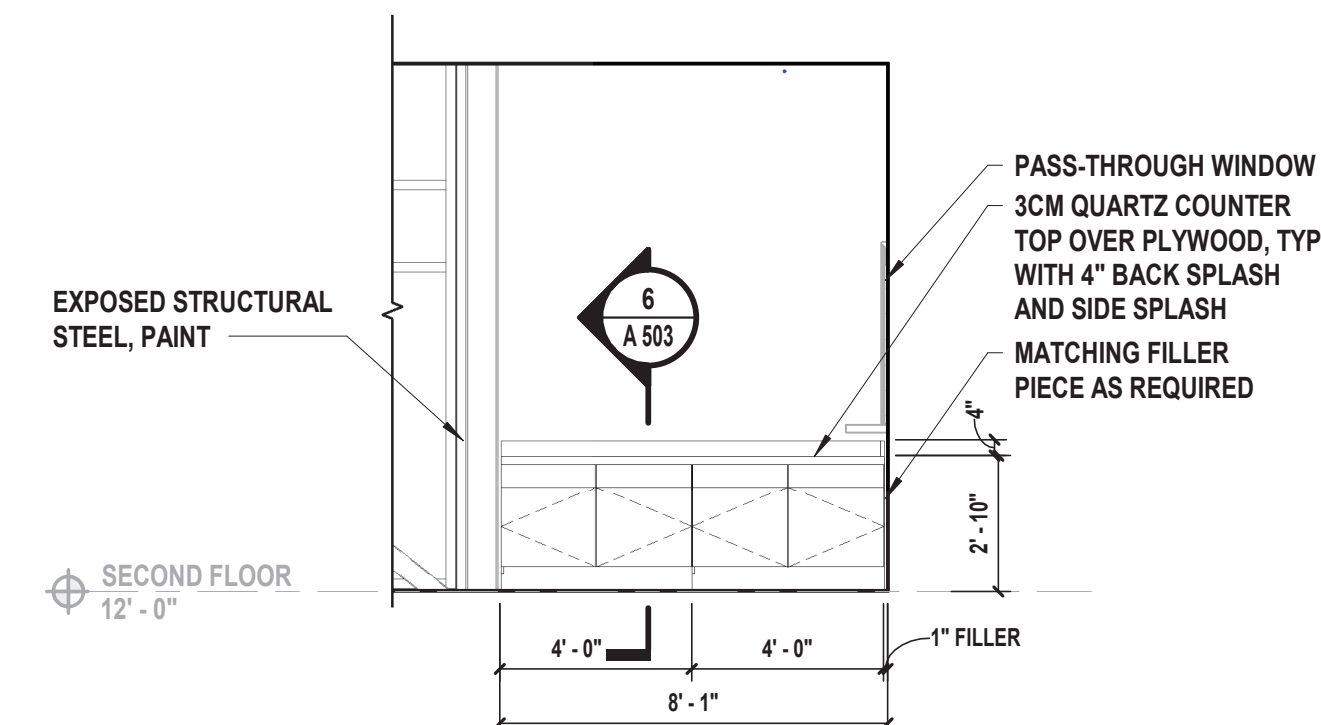

E Interior Elevation
SCALE: 1/4" = 1'-0"

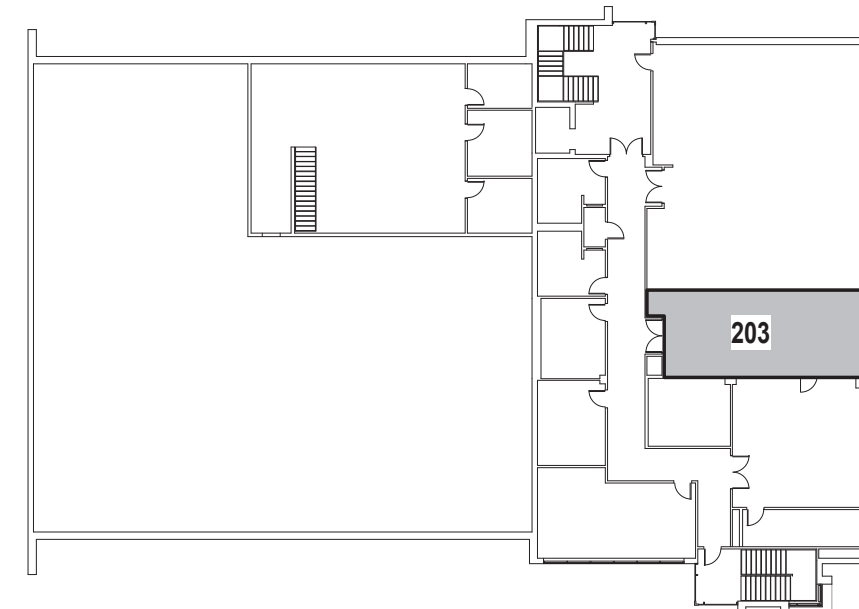

Second Floor Key Plan

SCALE: NTS

CONSULTANTS:

MARK	DATE	DESCRIPTION

REGISTERED ARCHITECT
PATRICK O. STONE, R.A.
STATE OF NEW YORK
029654
10/31/2025
Exp. Date
NY PROFESSIONAL ARCHITECT LIC. NO. 009654
"IN ACCORDANCE WITH ARTICLE 145, SECTION 1209 OF THE NYS EDUCATION LAW,
ALTAUTION OF THIS DOCUMENT EXCEPT BY A LICENSED PROFESSIONAL IS ILLEGAL."

DESIGNED BY:	DRAWN BY:	CHECKED BY:	REVIEWED BY:
DBS/RLG	ANK	DBS	POS
PROJECT No:	DATE:	SCALE:	AS SHOWN
TRFD 2302	FEBRUARY 2025		

CLIENT
**THIELLS
ROSEVILLE FIRE
DISTRICT**

NEW 26-100 FIRE
HEADQUARTERS

65 W RAMAPO ROAD
GARNERVILLE, NY 10923

CONTRACT
**CONTRACT G
GENERAL CONSTRUCTION**

STATUS
FINAL BID DOCUMENT

SHEET TITLE
**ENLARGED MULTI-PURPOSE
ROOM SERVICE AREA & INTERIOR
ELEVATIONS**

DRAWING No.
A 424.00

CONSULTANTS:		

MARK	DATE	DESCRIPTION

REGISTERED ARCHITECT
PATRICK O. STONE
STATE OF NEW YORK
029654


PATRICK O. STONE, R.A.
NY PROFESSIONAL ARCHITECT LIC. NO. 029654
Exp. Date: 10/31/2025

DESIGNED BY: DBS/RLG
PROJECT No: TRFD 2302

DRAWN BY: ANK
DATE: FEBRUARY 2025

CHECKED BY: DBS
SCALE: AS SHOWN

REVIEWED BY: POS

CLIENT

THIELLS
ROSEVILLE FIRE
DISTRICT

NEW 26-100 FIRE
HEADQUARTERS



65 W RAMAPO ROAD
GARNERVILLE, NY 10923

CONTRACT

CONTRACT G
GENERAL CONSTRUCTION

STATUS



FINAL BID DOCUMENT

SHEET TITLE


ENLARGED KITCHEN PLAN,
INTERIOR ELEVATIONS &
EQUIPMENT SCHEDULE

DRAWING No.


A 425.00

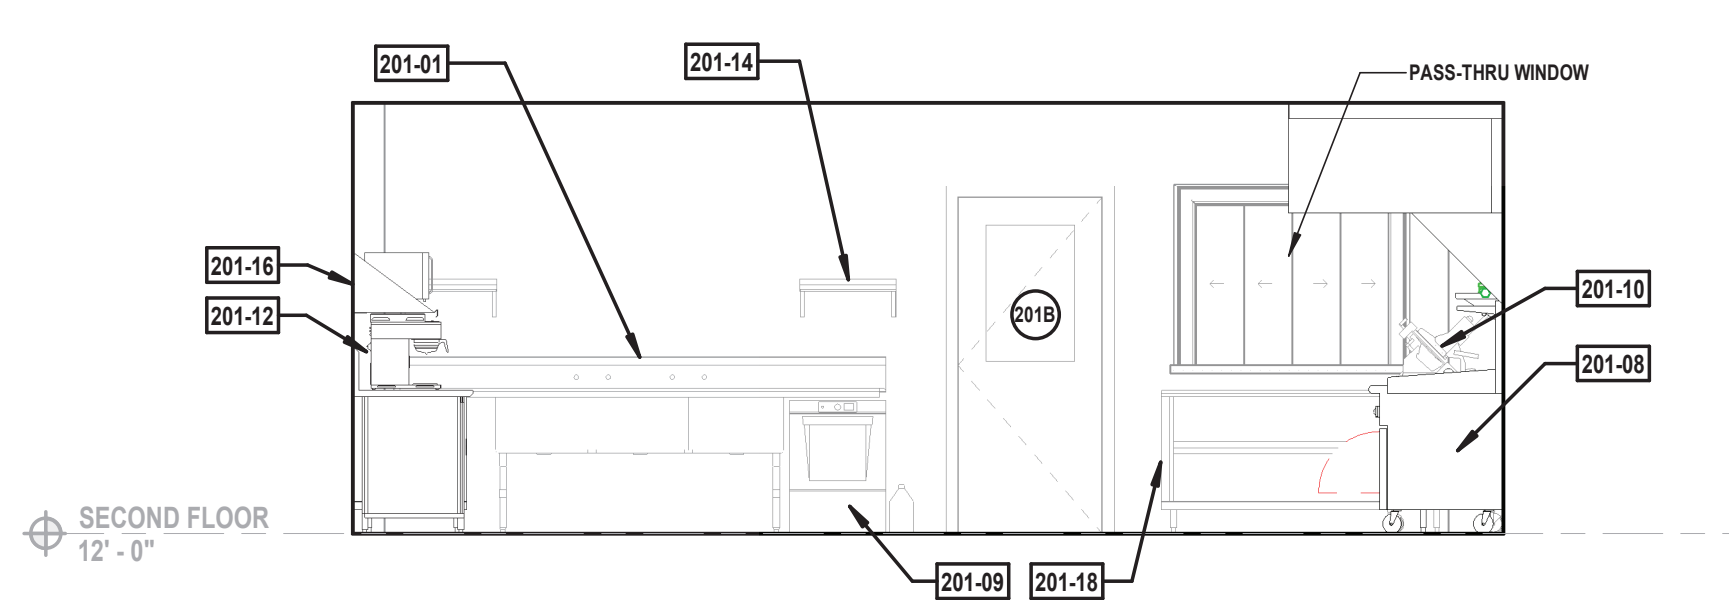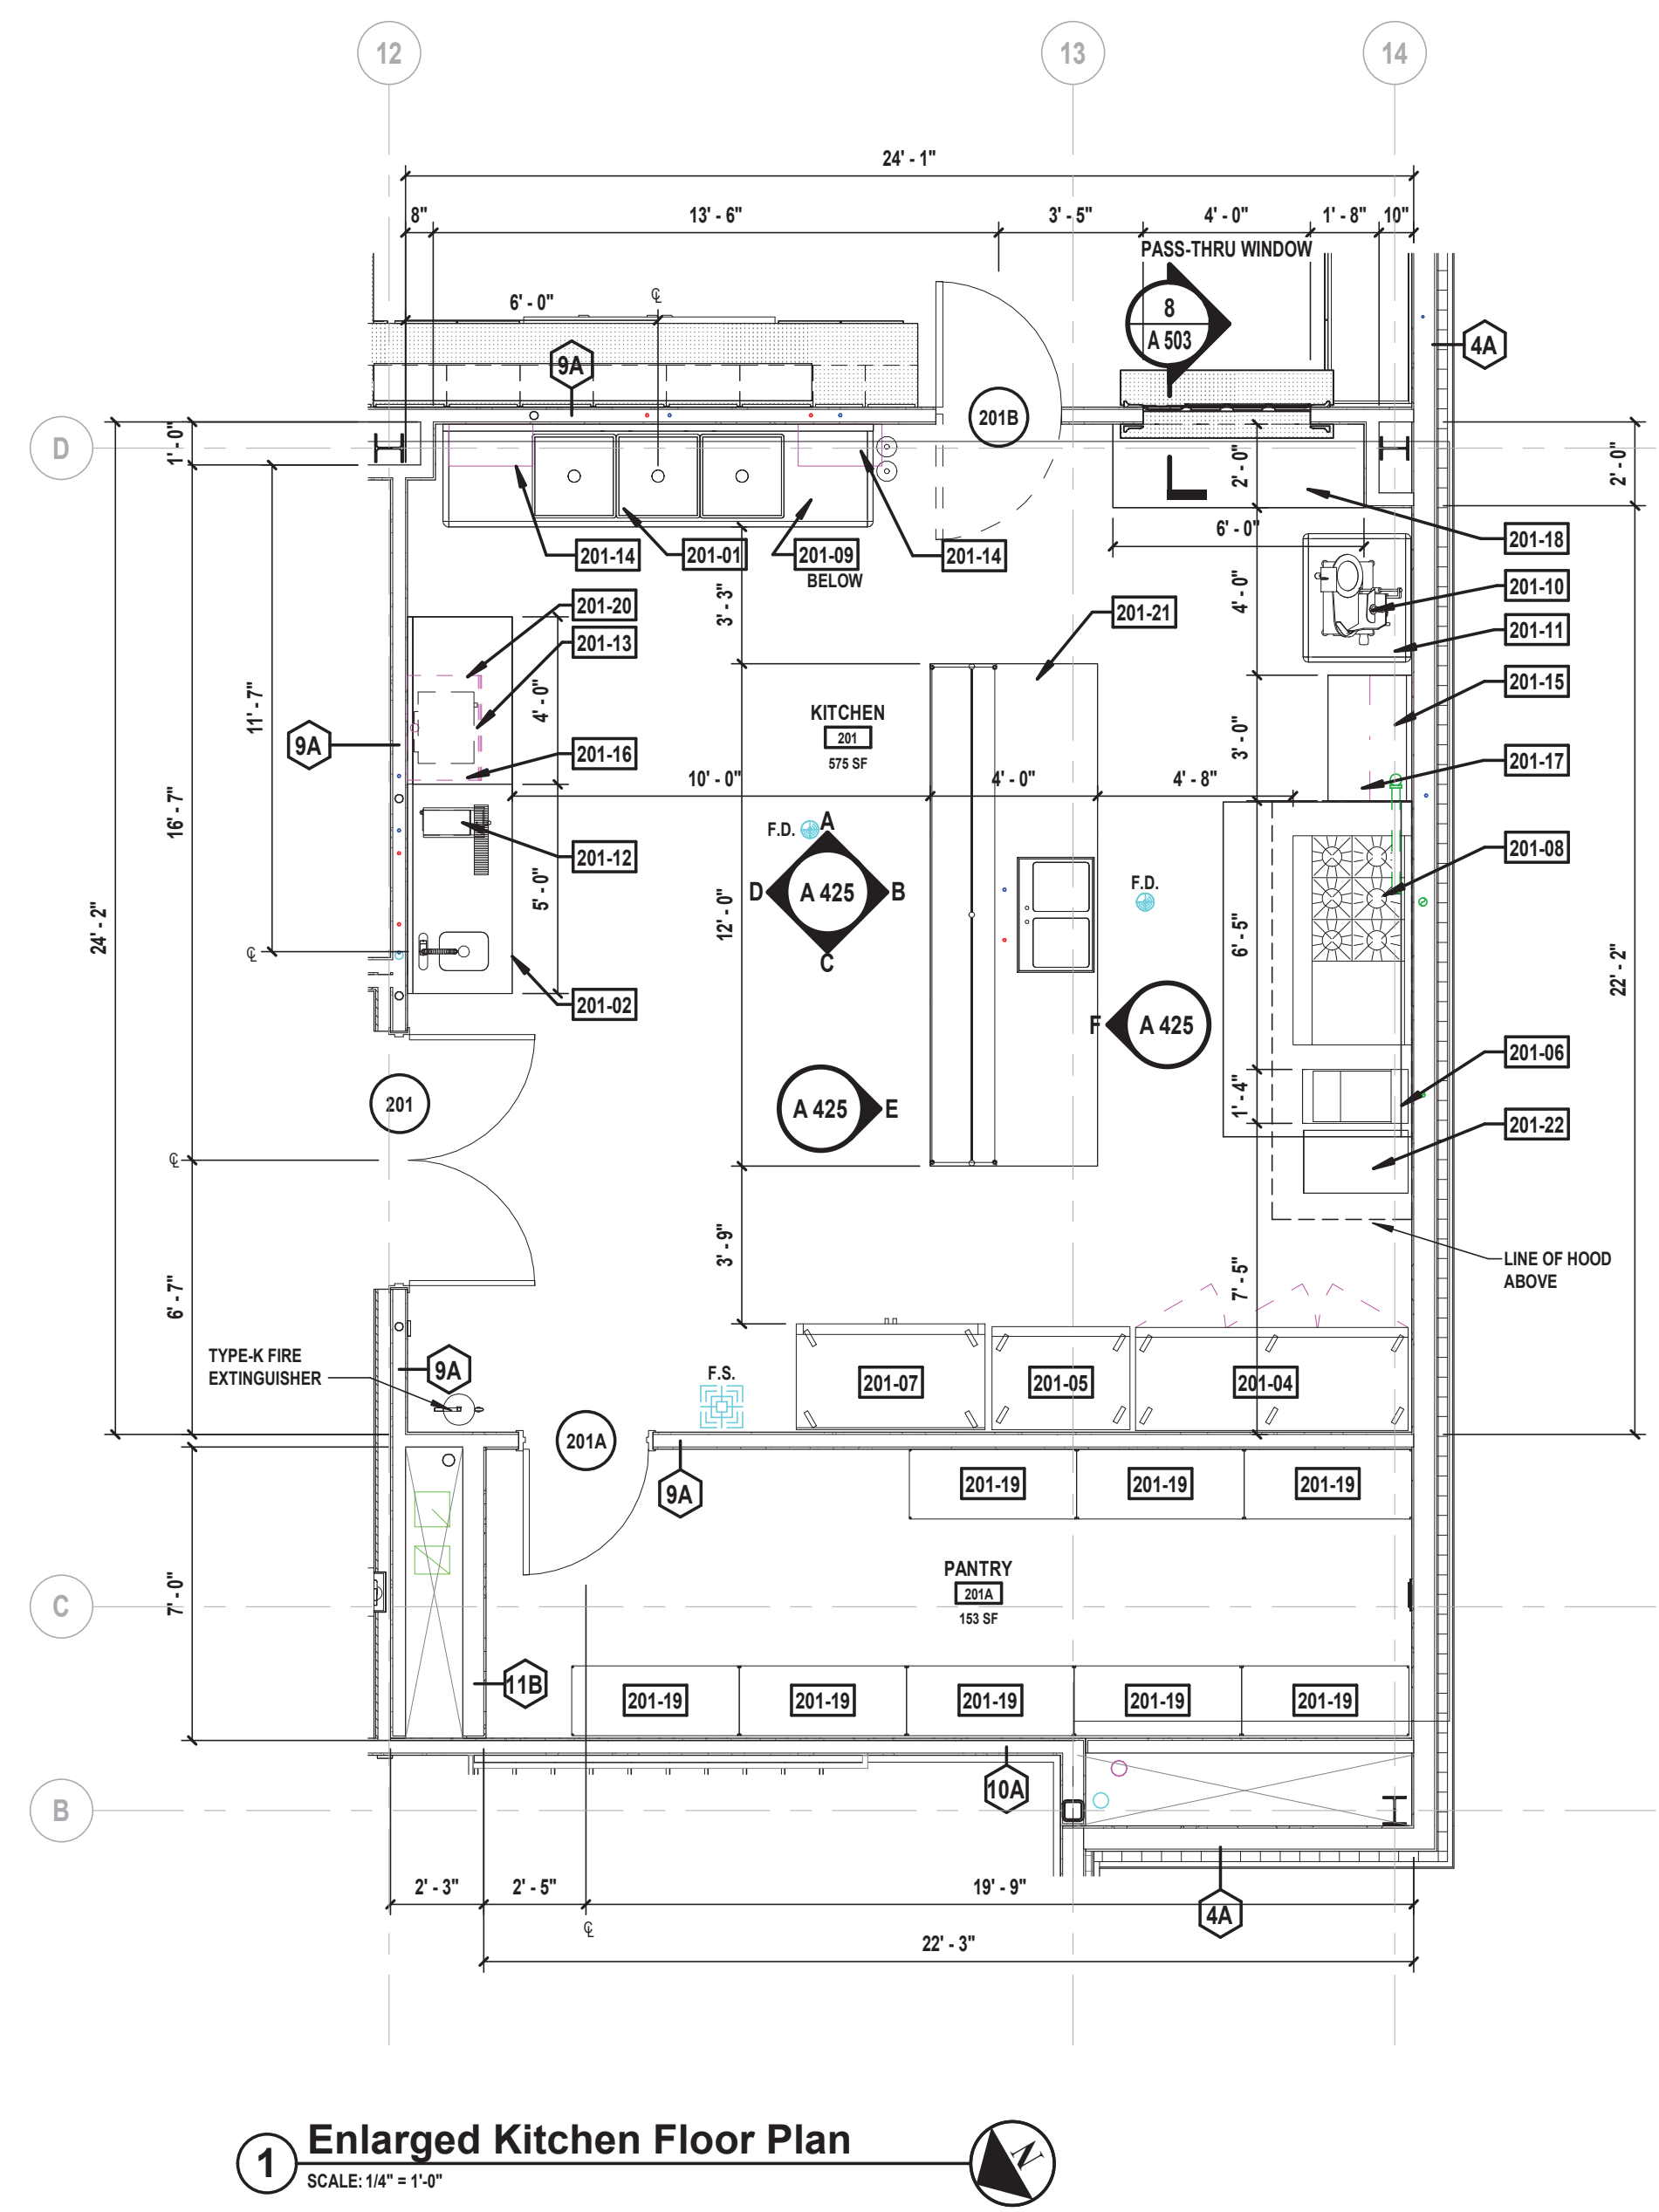


A Interior Elevation
SCALE: 1/4" = 1'-0"

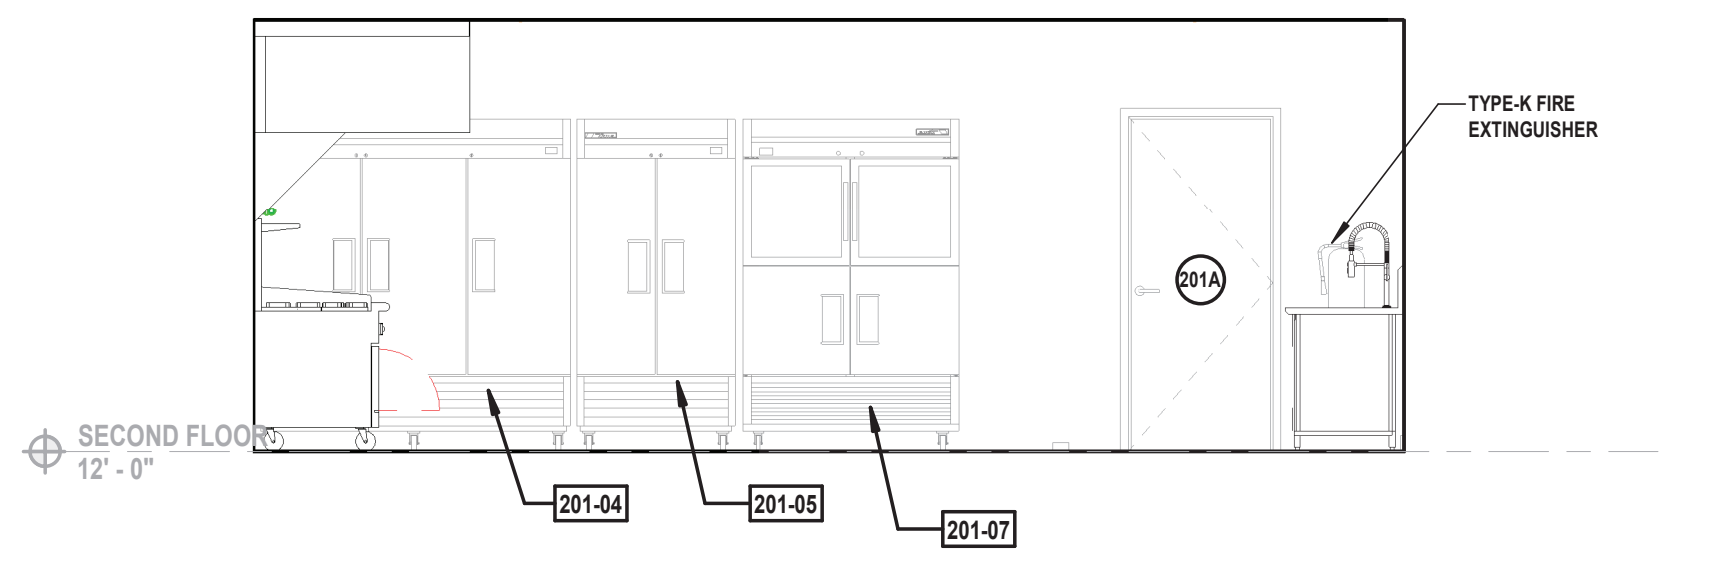


C Interior Elevation
SCALE: 1/4" = 1'-0"

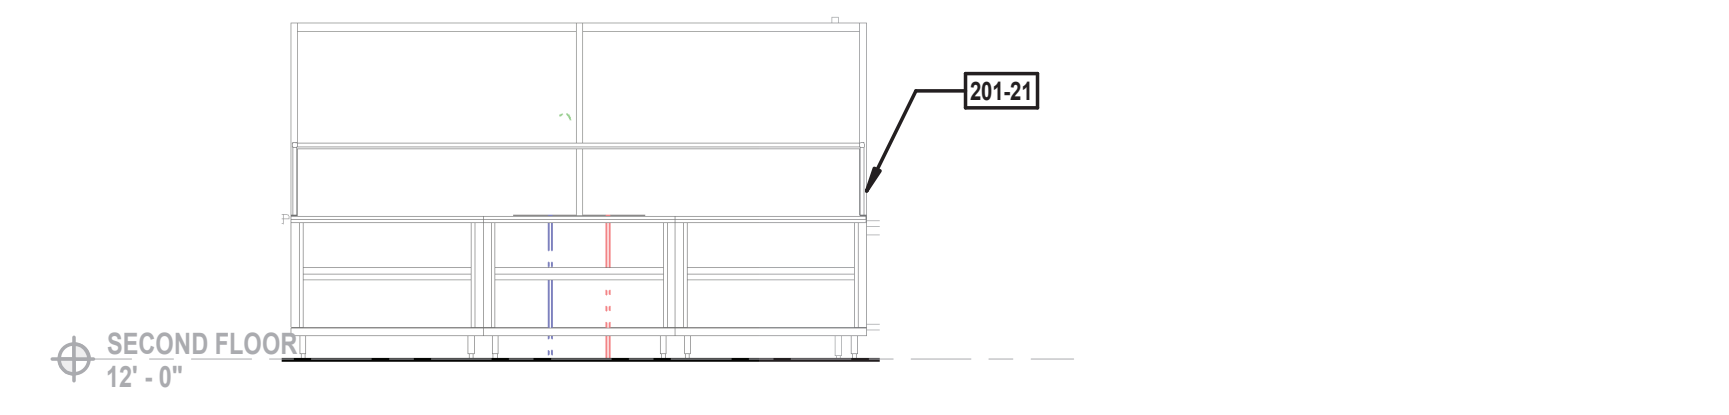


E Island Elevation
SCALE: 1/4" = 1'-0"

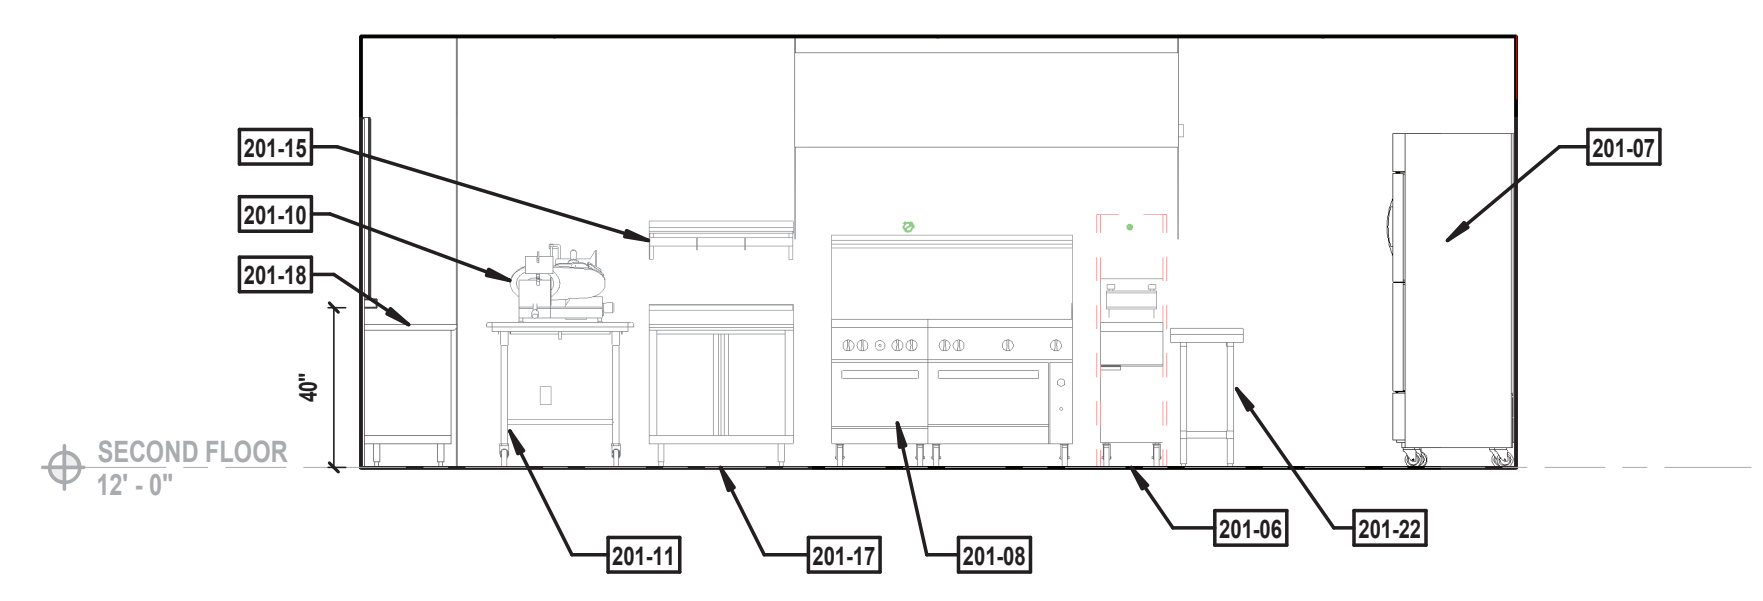

B Interior Elevation
SCALE: 1/4" = 1'-0"

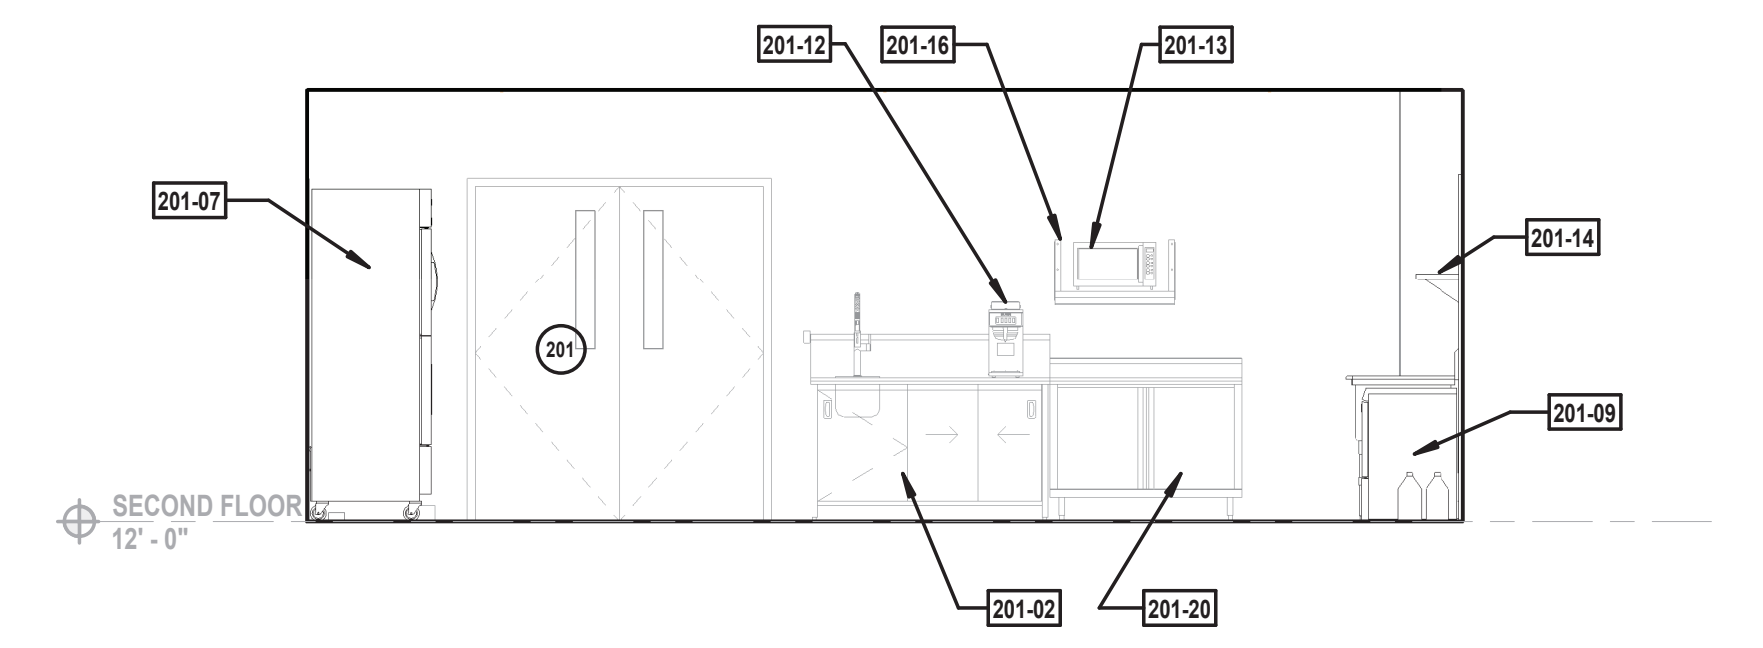

D Interior Elevation
SCALE: 1/4" = 1'-0"

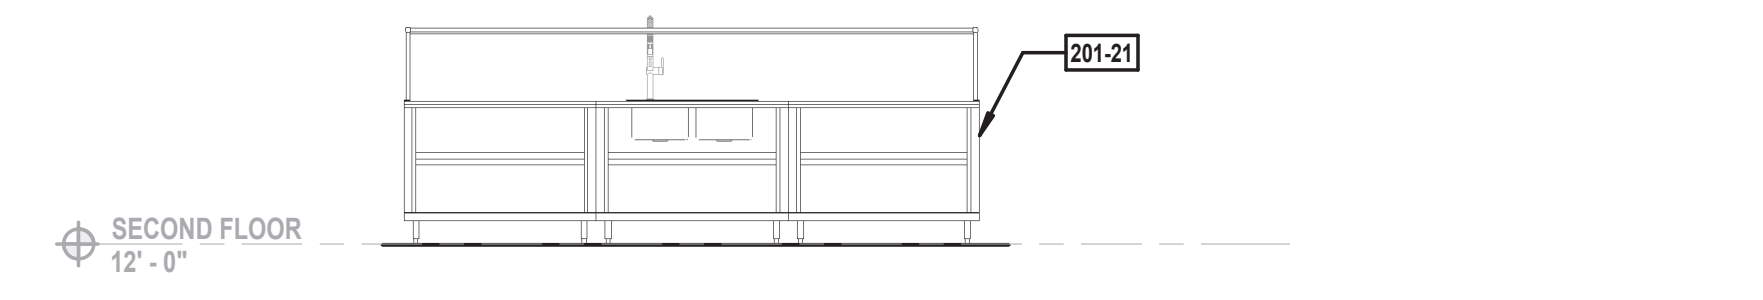

F Interior Elevation
SCALE: 1/4" = 1'-0"

- FOOD SERVICE EQUIPMENT NOTES
1.

INSTALL FOOD SERVICE EQUIPMENT LEVEL AND PLUMB, ACCORDING TO MANUFACTURER'S WRITTEN INSTRUCTIONS.
2.

CONNECT ALL EQUIPMENT TO UTILITIES AS NEEDED FOR A COMPLETE AND FULLY FUNCTIONAL OPERATION.
3.

CONTRACT 'G' IS TO PROVIDE CUT OUTS IN EQUIPMENT AND CABINETRY AS REQUIRED FOR ALL UTILITY CONNECTIONS.
4.

PROVIDE CLOSED BUTT AND CONTACT JOINTS THAT DO NOT REQUIRE FILLER, GRIND FIELD WELDS ON STAINLESS STEEL EQUIPMENT UNTIL SMOOTH AND POLISH TO MATCH ADJACENT FINISH.
5.

INSTALL EQUIPMENT WITH ACCESS AND MAINTENANCE CLEARANCES THAT COMPLY WITH MANUFACTURER'S WRITTEN INSTALLATION INSTRUCTIONS.
6.

INSTALL SEALANT IN JOINTS BETWEEN EQUIPMENT AND ABUTTING SURFACES WITH CONTINUOUS JOINT BACKING, UNLESS OTHER WISE INDICATED. PROVIDE AIRTIGHT, WATERTIGHT, VERMIN-PROOF SANITARY JOINTS.
7.

AFTER EQUIPMENT INSTALL IS COMPLETE, REPAIR DAMAGED FINISHES.
8.


CLEAN AND ADJUST EQUIPMENT AS REQUIRED TO PRODUCE READY-FOR-USE CONDITION.
9.


PROTECT EQUIPMENT FROM DAMAGE DURING REMAINDER OF THE CONSTRUCTION PERIOD.
10.

ENGAGE A FACTORY AUTHORIZED SERVICE REPRESENTATIVE TO TRAIN OWNER'S MAINTENANCE PERSONNEL TO ADJUST, OPERATE AND MAINTAIN FOOD SERVICE EQUIPMENT.
11.


CONTRACT 'G' TO PROVIDE ALL REQUIRED ACCESSORIES FOR A COMPLETE AND READY-FOR-USE INSTALLATION.

EQUIPMENT SCHEDULE - KITCHEN 201				
MARK	MANUFACTURER	MODEL	DESCRIPTION	COMMENTS
201-01	JOHN BOOS	3B244-2D24	SINK, 3 COMPARTMENT	WITH (2) KROWNE 18-706L FAUCETS. N.I.C. PROVIDED BY OWNER, CONNECTIONS BY CONTRACT P
201-02	ADVANCE TABCO		ENCLOSED BASE WITH DROP-IN HAND SINK	EXISTING TO BE REUSED, CONNECTIONS BY CONTRACT P
201-04	TRUE	T-72-HC	REACH-IN SOLID SWING DOOR REFRIGERATOR	EXISTING TO BE REUSED
201-05	TRUE	TS-35F-HC	REACH-IN SOLID SWING DOOR FREEZER	N.I.C. PROVIDED BY OWNER
201-06	VULCAN	1GR45M	FREE STANDING GAS FRYER	EXISTING TO BE REUSED
201-07	TRUE	TS-49-2-G-2-HC-FGD01	REACH-IN COMBINATION HAFT SWING DOOR	N.I.C. PROVIDED BY OWNER
201-08	Vulcan	60SS-6B-24G	60" WIDE GAS RANGE (6 BURNER, 24" GRIDDLE, 2 OVENS)	N.I.C. PROVIDED BY OWNER, CONNECTIONS BY CONTRACT P
201-09	HOBART	LXnH-208V	UNDERCOUNTER DISHWASHER	N.I.C. PROVIDED BY OWNER, CONNECTIONS BY CONTRACT P
201-10	HOBART	EDGE 13	ELECTRIC SLICER	N.I.C. PROVIDED BY OWNER
201-11	JOHN BOOS	DST6-3037SBW-C	SORTING TABLE WITH CASTERS	N.I.C. PROVIDED BY OWNER
201-12	BUNN	CWTF35-3T	AUTOMATIC COFFEE BREWER (2U/1L WARMER)	N.I.C. PROVIDED BY OWNER
201-13	VOLLRATH	40819	MICROWAVE	N.I.C. PROVIDED BY OWNER
201-14	JOHN BOOS	BHS1224PR	STAINLESS STEEL WALL SHELF	N.I.C. PROVIDED BY OWNER
201-15	JOHN BOOS	BHS1236PR	STAINLESS STEEL WALL SHELF	N.I.C. PROVIDED BY OWNER
201-16	JOHN BOOS	BMS2030	STAINLESS MICROWAVE SHELF	N.I.C. PROVIDED BY OWNER
201-17	JOHN BOOS	4CH4	STAINLESS MODULAR BASE WORK TABLE W/ 5" BACKSPLASH - HINGED DOORS W/ DRAWERS	SEE PLAN FOR SIZES, N.I.C. PROVIDED BY OWNER
201-18	JOHN BOOS	4CO4-2472-1S	STAINLESS MODULAR BASE WORK TABLE W/ 5" BACK SPLASH - OPEN BASE, INTERMEDIATE SHELF	SEE PLAN FOR SIZES, N.I.C. PROVIDED BY OWNER
201-19	-	-	METAL SHELVING RACKS	EXISTING TO BE REUSED
201-20	ADVANCE TABCO		STAINLESS MODULAR BASE CABINET W/ 5" BACKSPLASH - HINGED DOORS W/ DRAWERS	EXISTING TO BE REUSED
201-21	JOHN BOOS	CUSTOM	CUSTOM CENTER ISLAND CONFIGURATION WITH INTEGRAL SINK, UNDERSHELF, TABLE MOUNTED OVERSHELF & POT RACK	N.I.C. PROVIDED BY OWNER, CONNECTIONS BY CONTRACT P
201-22	JOHN BOOS	EFT8-3018	WORK TABLE-FILLER	N.I.C. PROVIDED BY OWNER

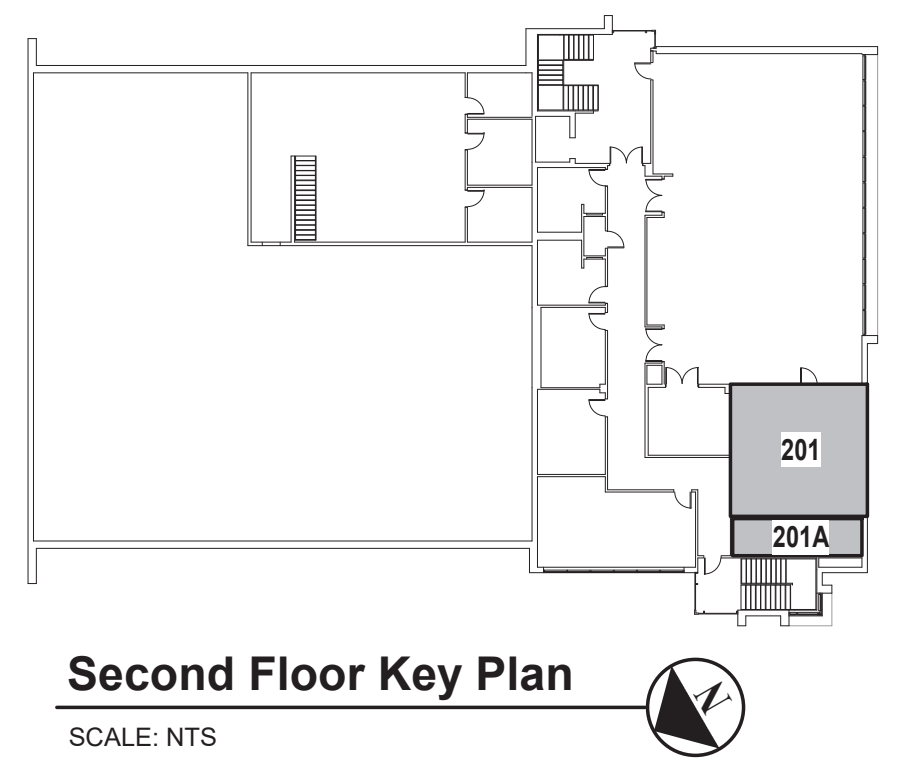


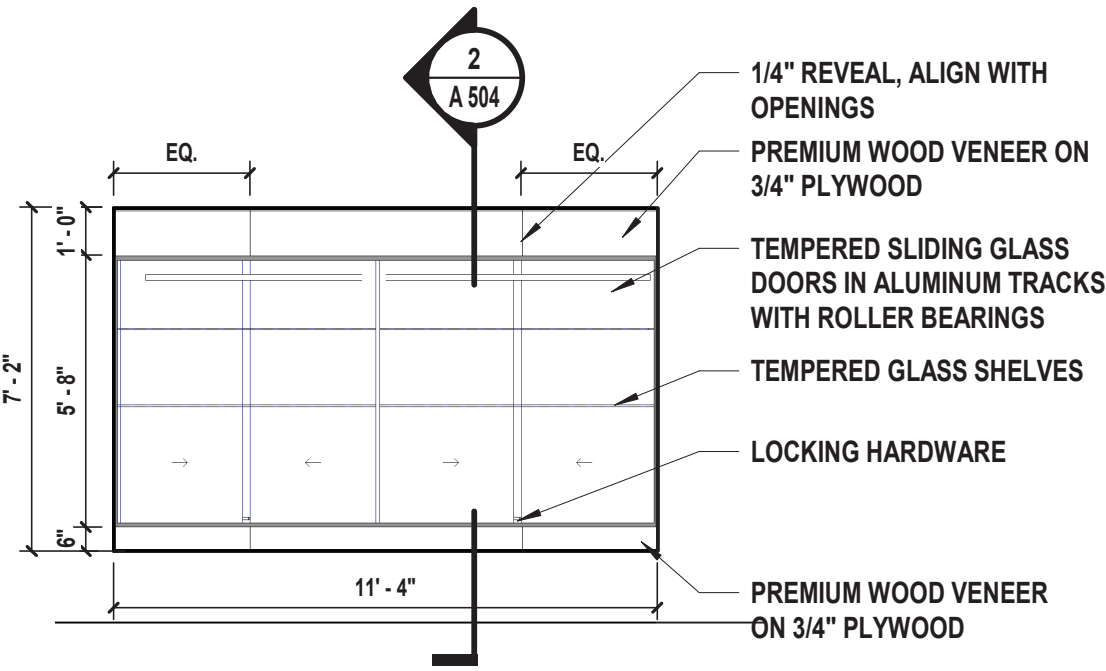

1 Display Case Elevation - Corridor
SCALE: 1/4" = 1'-0"

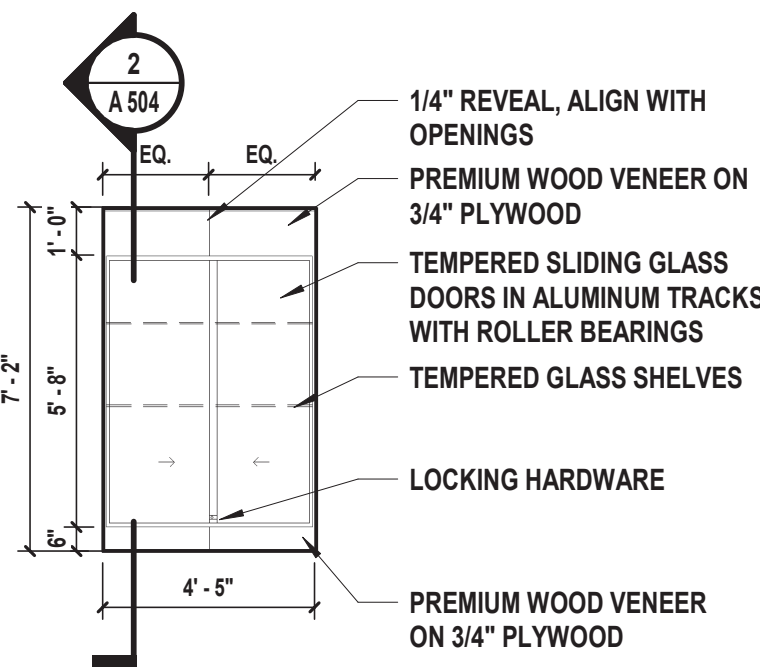

2 Display Case Elevation - Stair A
SCALE: 1/4" = 1'-0"

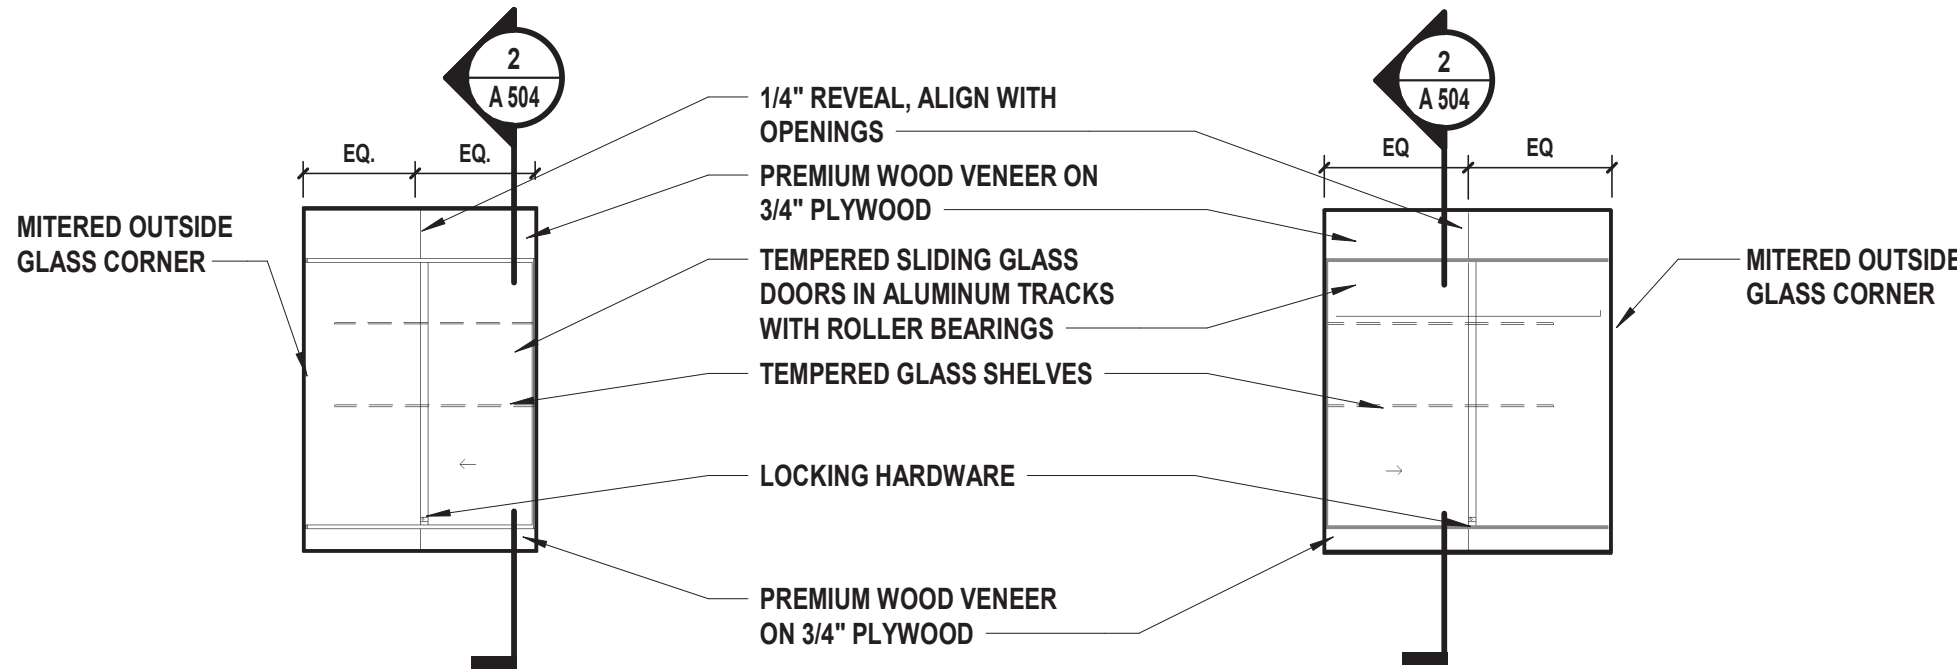

3 Display Case Elevation - Stair B
SCALE: 1/4" = 1'-0"

4 Display Case Elevation - Stair B
SCALE: 1/4" = 1'-0"

CONSULTANTS:		

MARK	DATE	DESCRIPTION



Patrick O. Stone
PATRICK O. STONE, R.A.
NY PROFESSIONAL ARCHITECT LIC. NO. 039654

10/31/2025
Exp. Date

*IN ACCORDANCE WITH ARTICLE 145, SECTION 1209 OF THE NYS EDUCATION LAW,
ALTACTION OF THIS DOCUMENT EXCEPT BY A LICENSED PROFESSIONAL IS ILLEGAL.

DESIGNED BY:	DRAWN BY:	CHECKED BY:	REVIEWED BY:
DBS/RLG	KAP	DBS	POS
PROJECT No:	DATE:	SCALE:	
TRFD 2302	FEBRUARY 2025	AS SHOWN	

CLIENT

**THIELLS
ROSEVILLE FIRE
DISTRICT**

**NEW 26-100 FIRE
HEADQUARTERS**



**65 W RAMAPO ROAD
GARNERVILLE, NY 10923**

CONTRACT

**CONTRACT G
GENERAL CONSTRUCTION**

STATUS


FINAL BID DOCUMENT

SHEET TITLE


**DISPLAY CASE INTERIOR
ELEVATIONS**

DRAWING No.


A 427.00

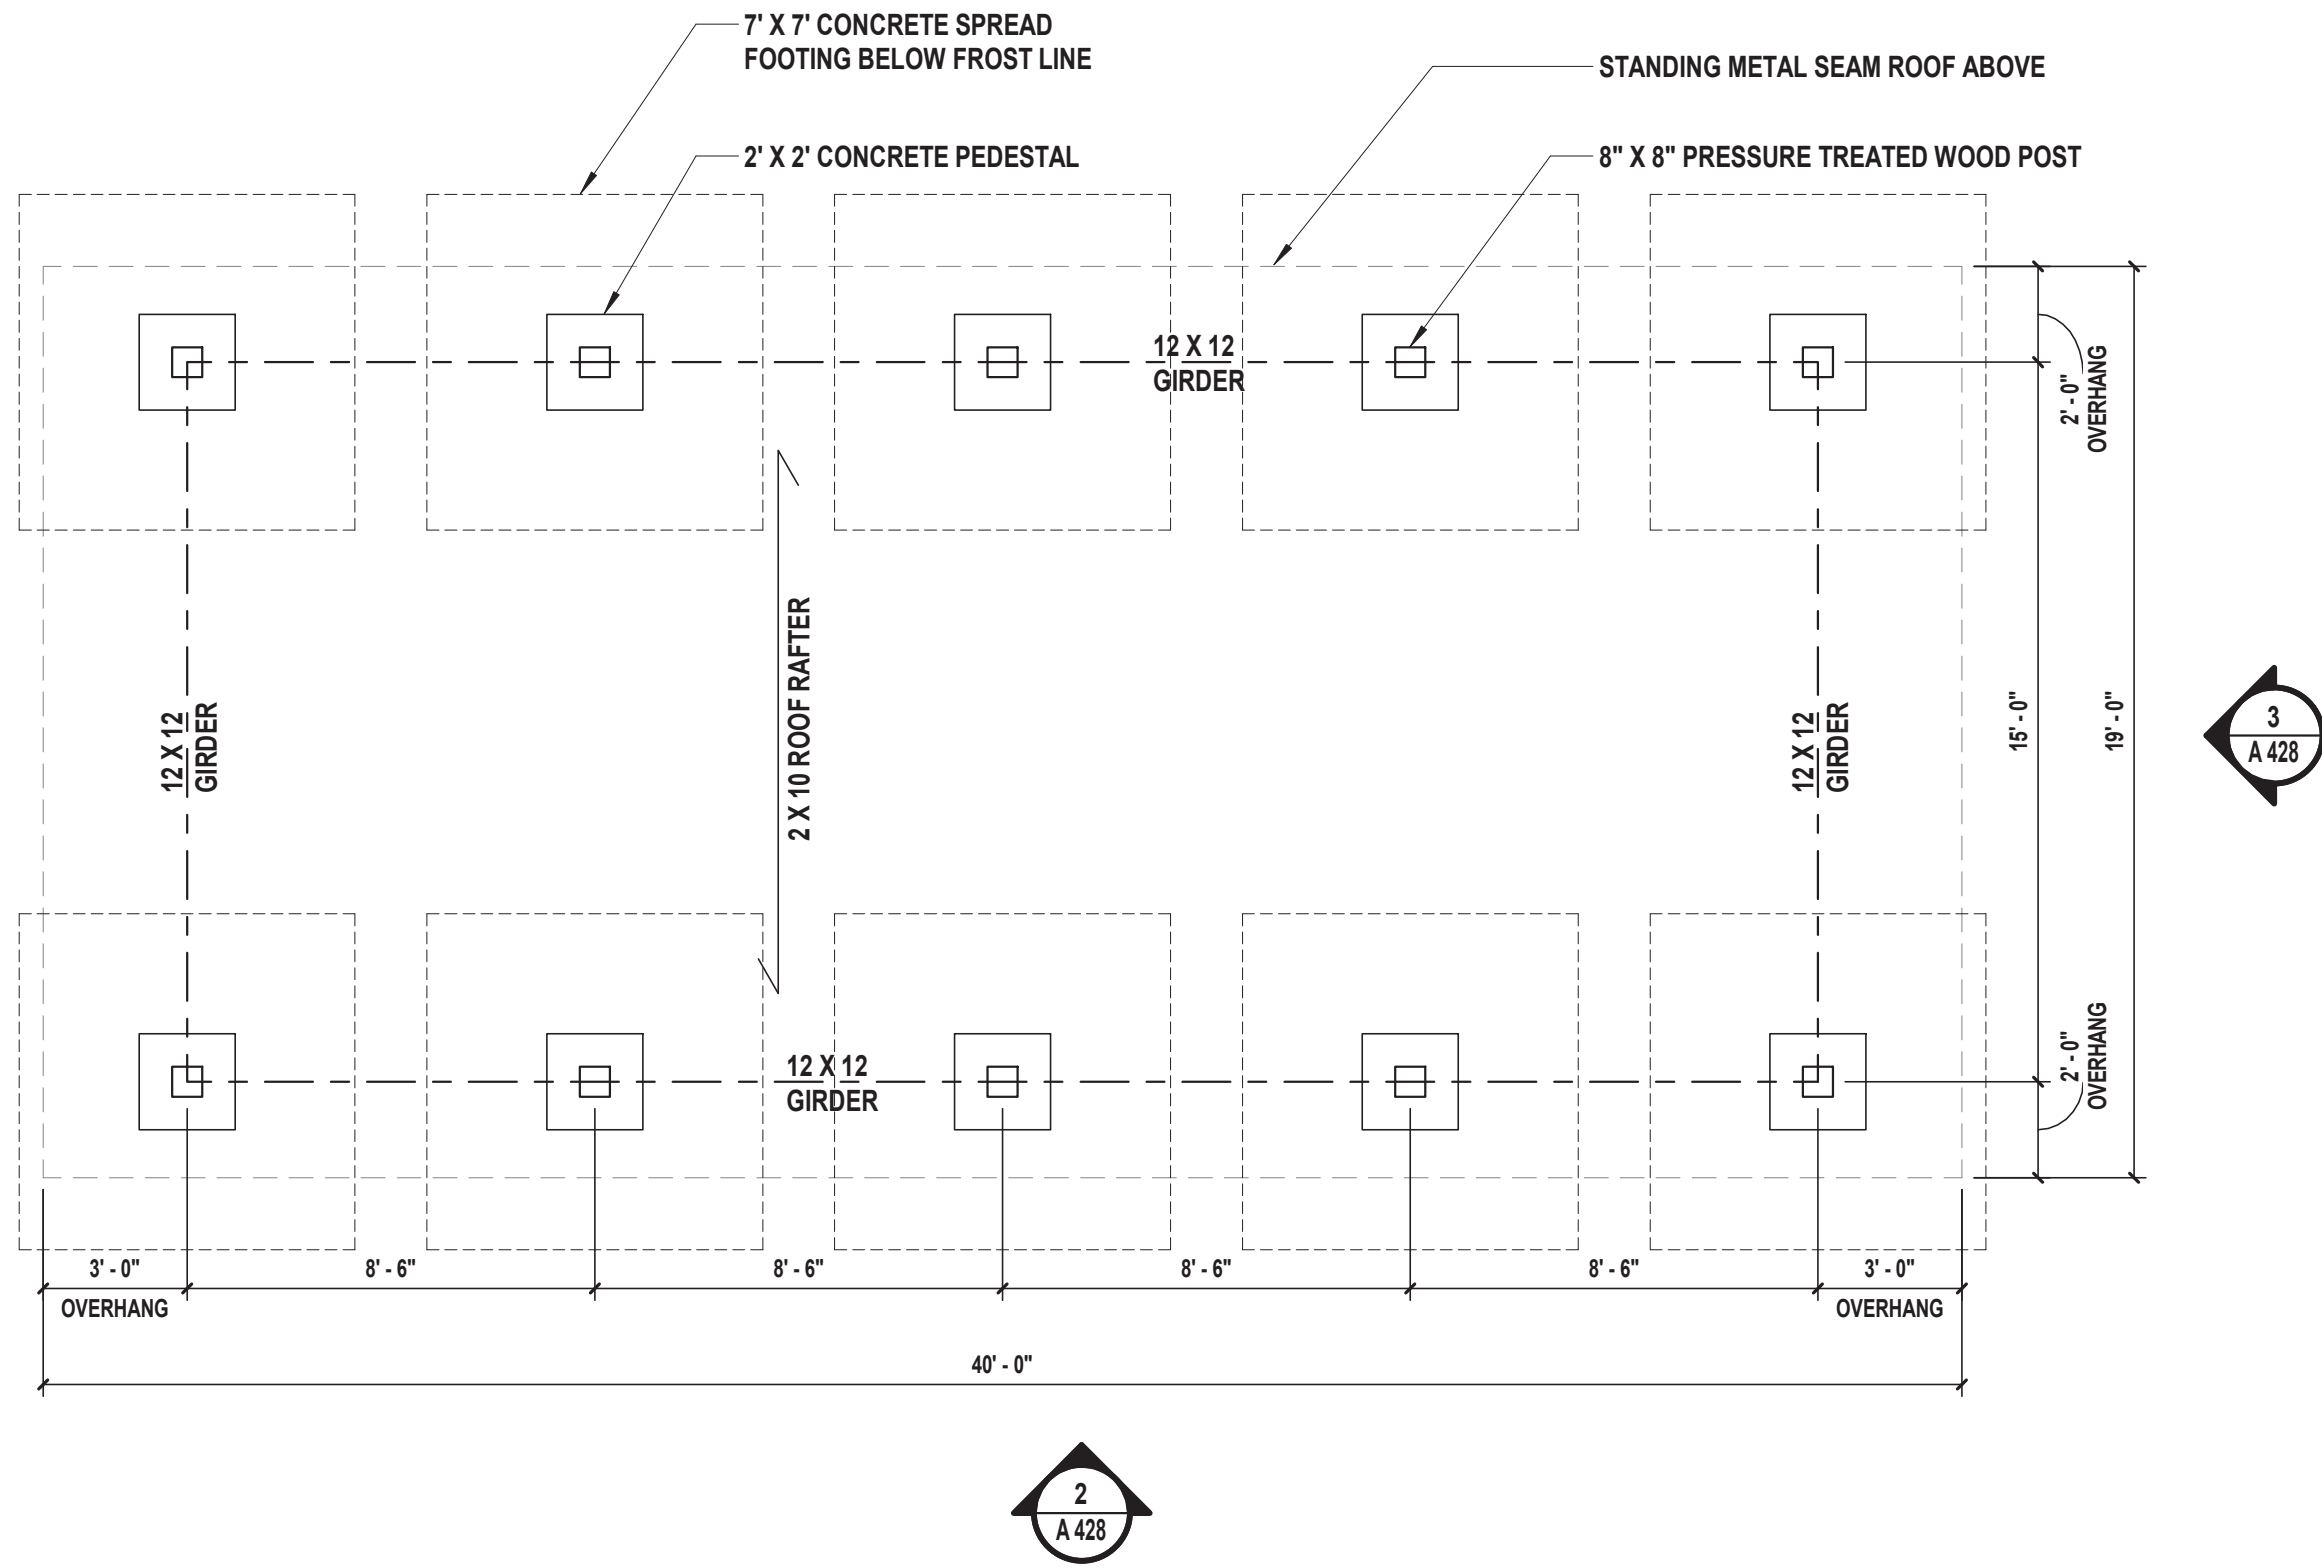

1 Pavilion Floor Plan
SCALE: 1/4" = 1'-0"

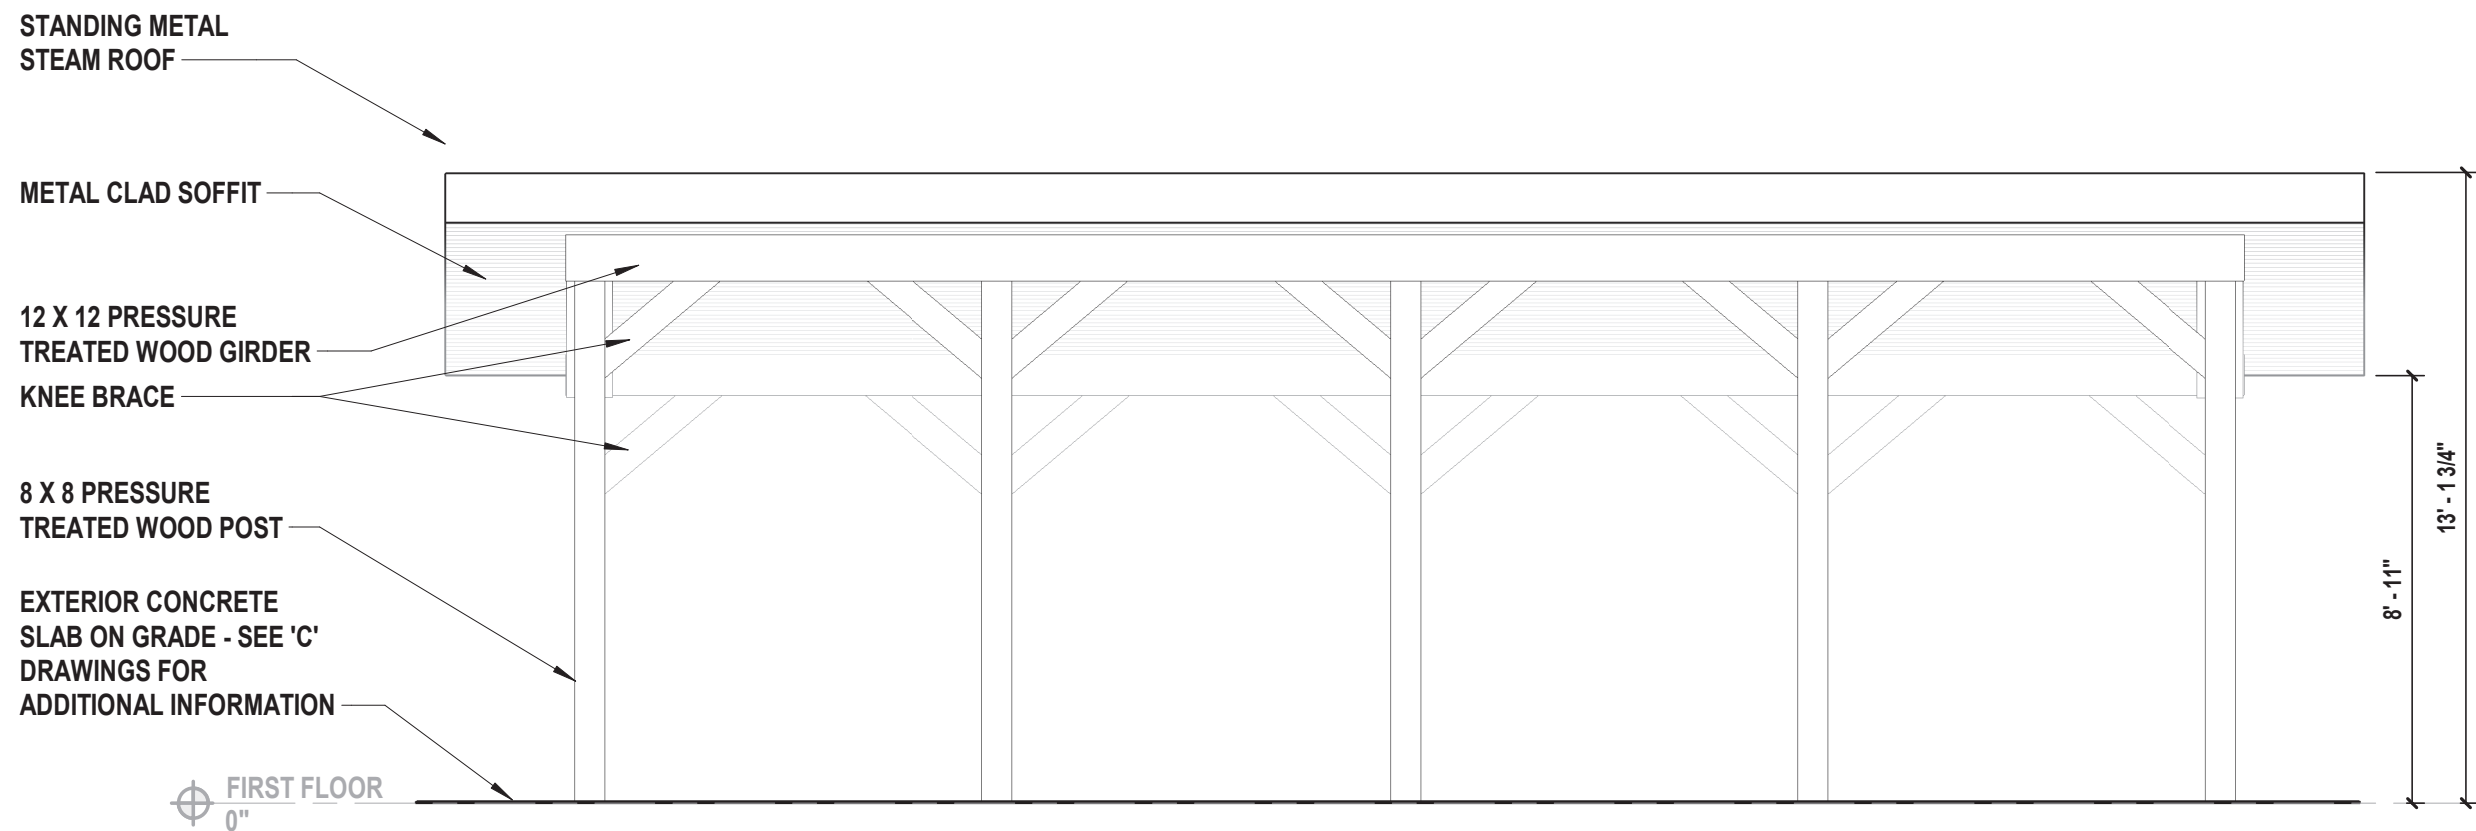


2 Pavilion West Elevation
SCALE: 1/4" = 1'-0"

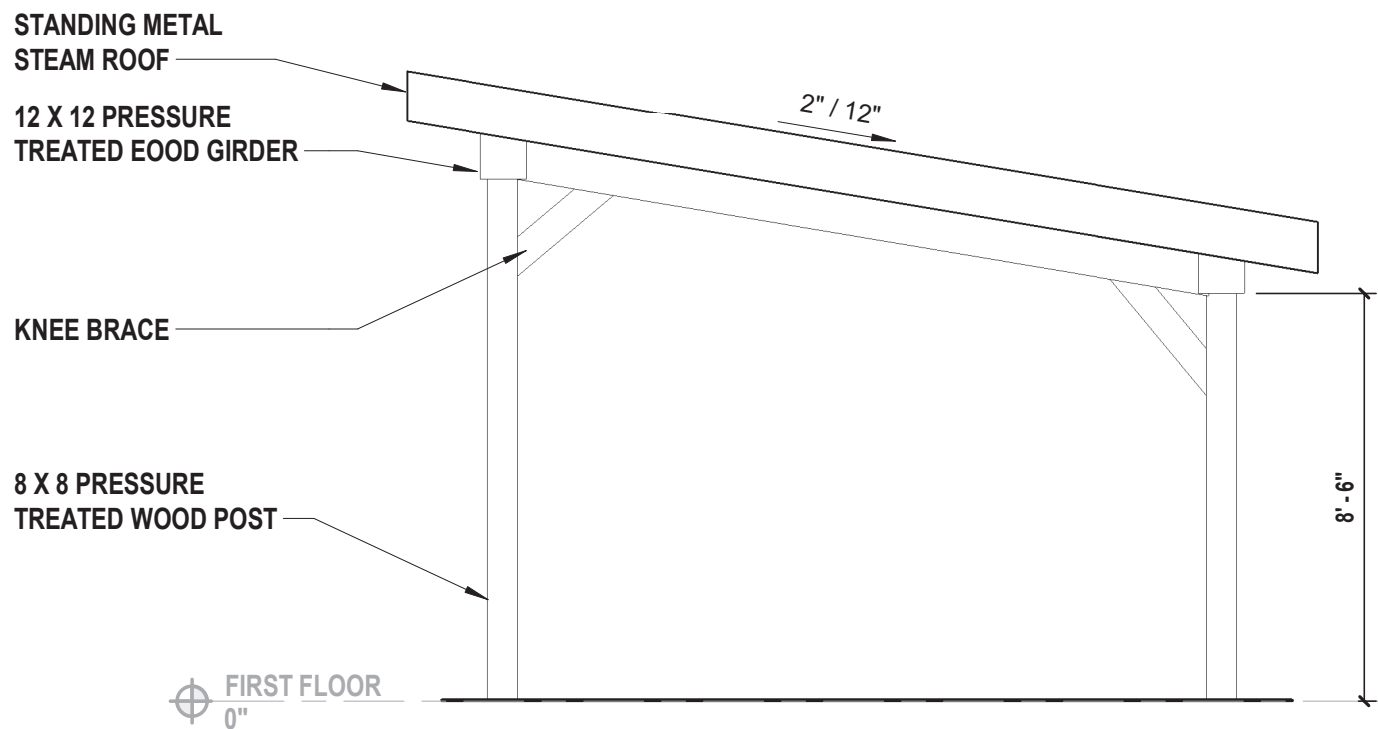

3 Pavilion South Elevation
SCALE: 1/4" = 1'-0"

GENERAL NOTES

- ALL STRUCTURAL MEMBERS SHOWN ON THIS SHEET ARE SHOWN FOR CONTRACTOR PRICING ONLY. ACTUAL SIZES AND REINFORCEMENT OF MEMBERS ARE TO BE DESIGNED BY CONTRACTORS ENGINEER AND SENT TO EOR FOR APPROVAL. SEE S 001 FOR STRUCTURAL DESIGN CRITERIA.

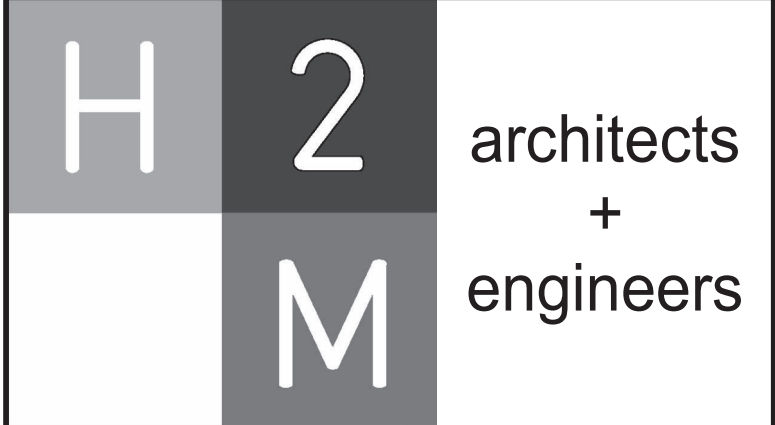

538 Broad Hollow Road, 4th Floor East
Melville, NY 11747
631.756.8000 • www.h2m.com
NY Architecture & Landscape Architecture: No Certificate Required
NY Engineering Certificate of Authorization No.: 0018178

CONSULTANTS:		

MARK	DATE	DESCRIPTION

10/31/2025
Exp. Date

PATRICK O. STONE, R.A.
NY PROFESSIONAL ARCHITECT LIC. NO. 039654

*IN ACCORDANCE WITH ARTICLE 145, SECTION 1209 OF THE NYS EDUCATION LAW, ALTERNATION OF THIS DOCUMENT EXCEPT BY A LICENSED PROFESSIONAL IS ILLEGAL.

DESIGNED BY:	DRAWN BY:	CHECKED BY:	REVIEWED BY:
DBS/RLG	ANK	DBS	POS
PROJECT No:	DATE:	SCALE:	AS SHOWN
TRFD 2302	FEBRUARY 2025		

CLIENT

**THIELLS
ROSEVILLE FIRE
DISTRICT**

**NEW 26-100 FIRE
HEADQUARTERS**

**65 W RAMAPO ROAD
GARNERVILLE, NY 10923**

CONTRACT

**CONTRACT G
GENERAL CONSTRUCTION**

STATUS








FINAL BID DOCUMENT

SHEET TITLE

**ENLARGED EXTERIOR PAVILION
PLAN AND ELEVATIONS**

DRAWING No.

A 428.00

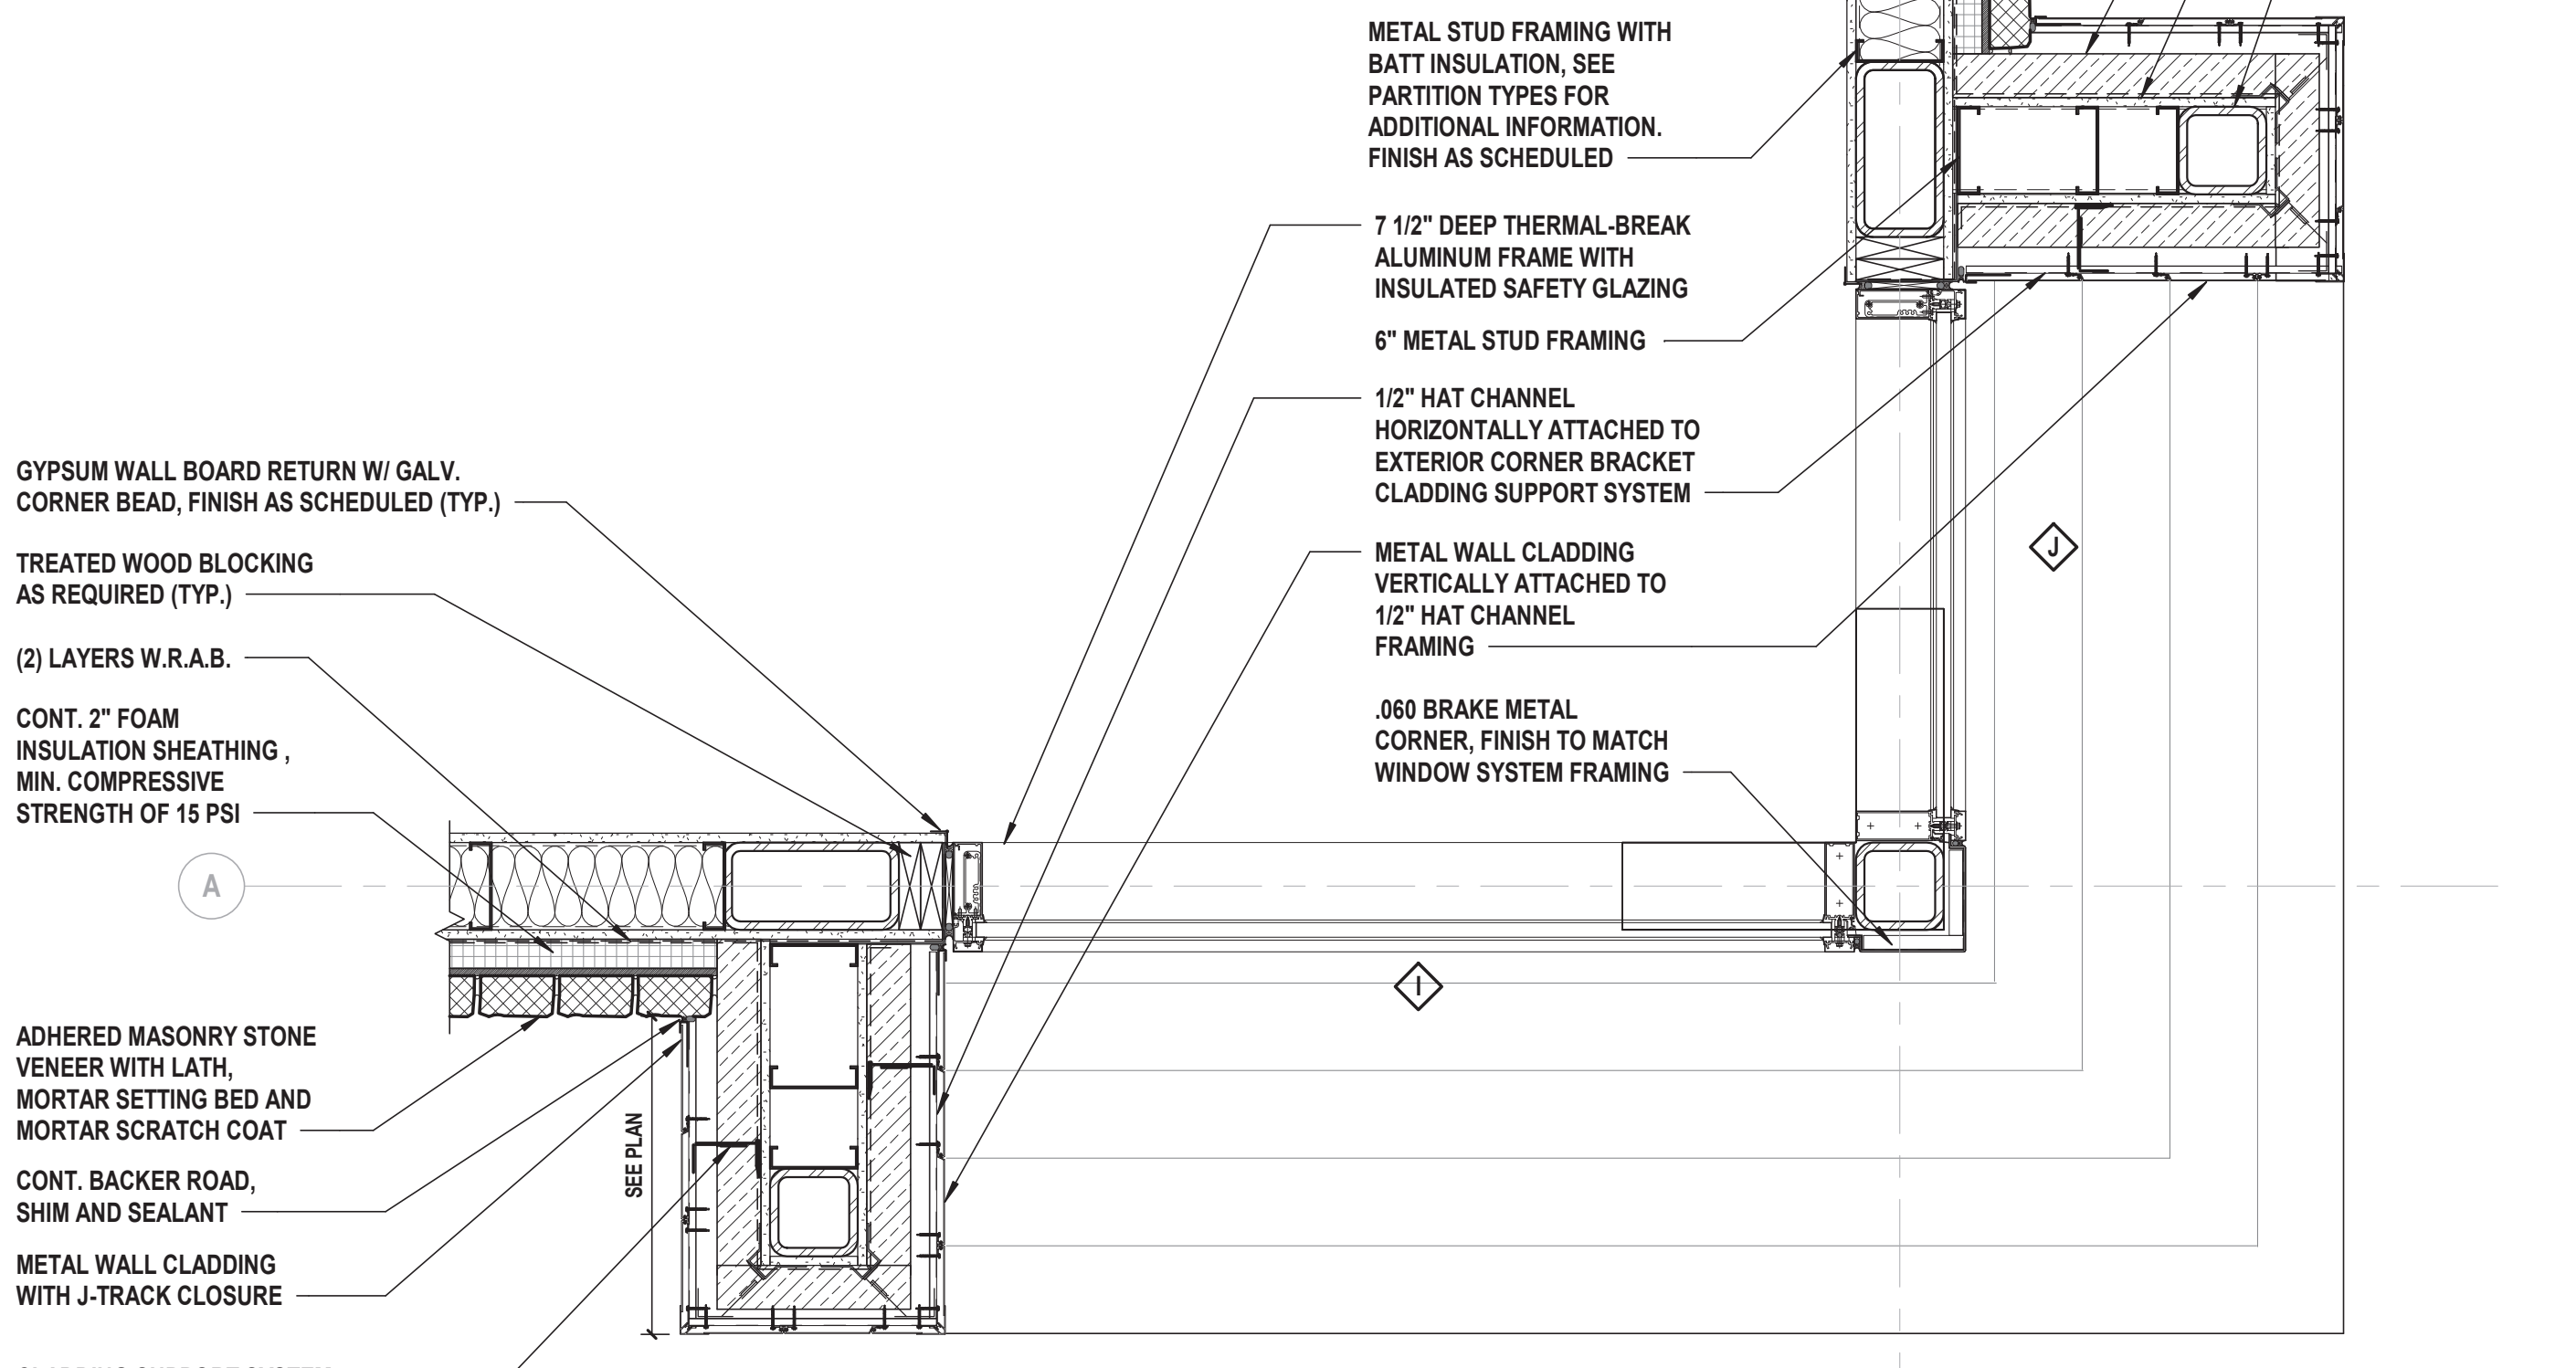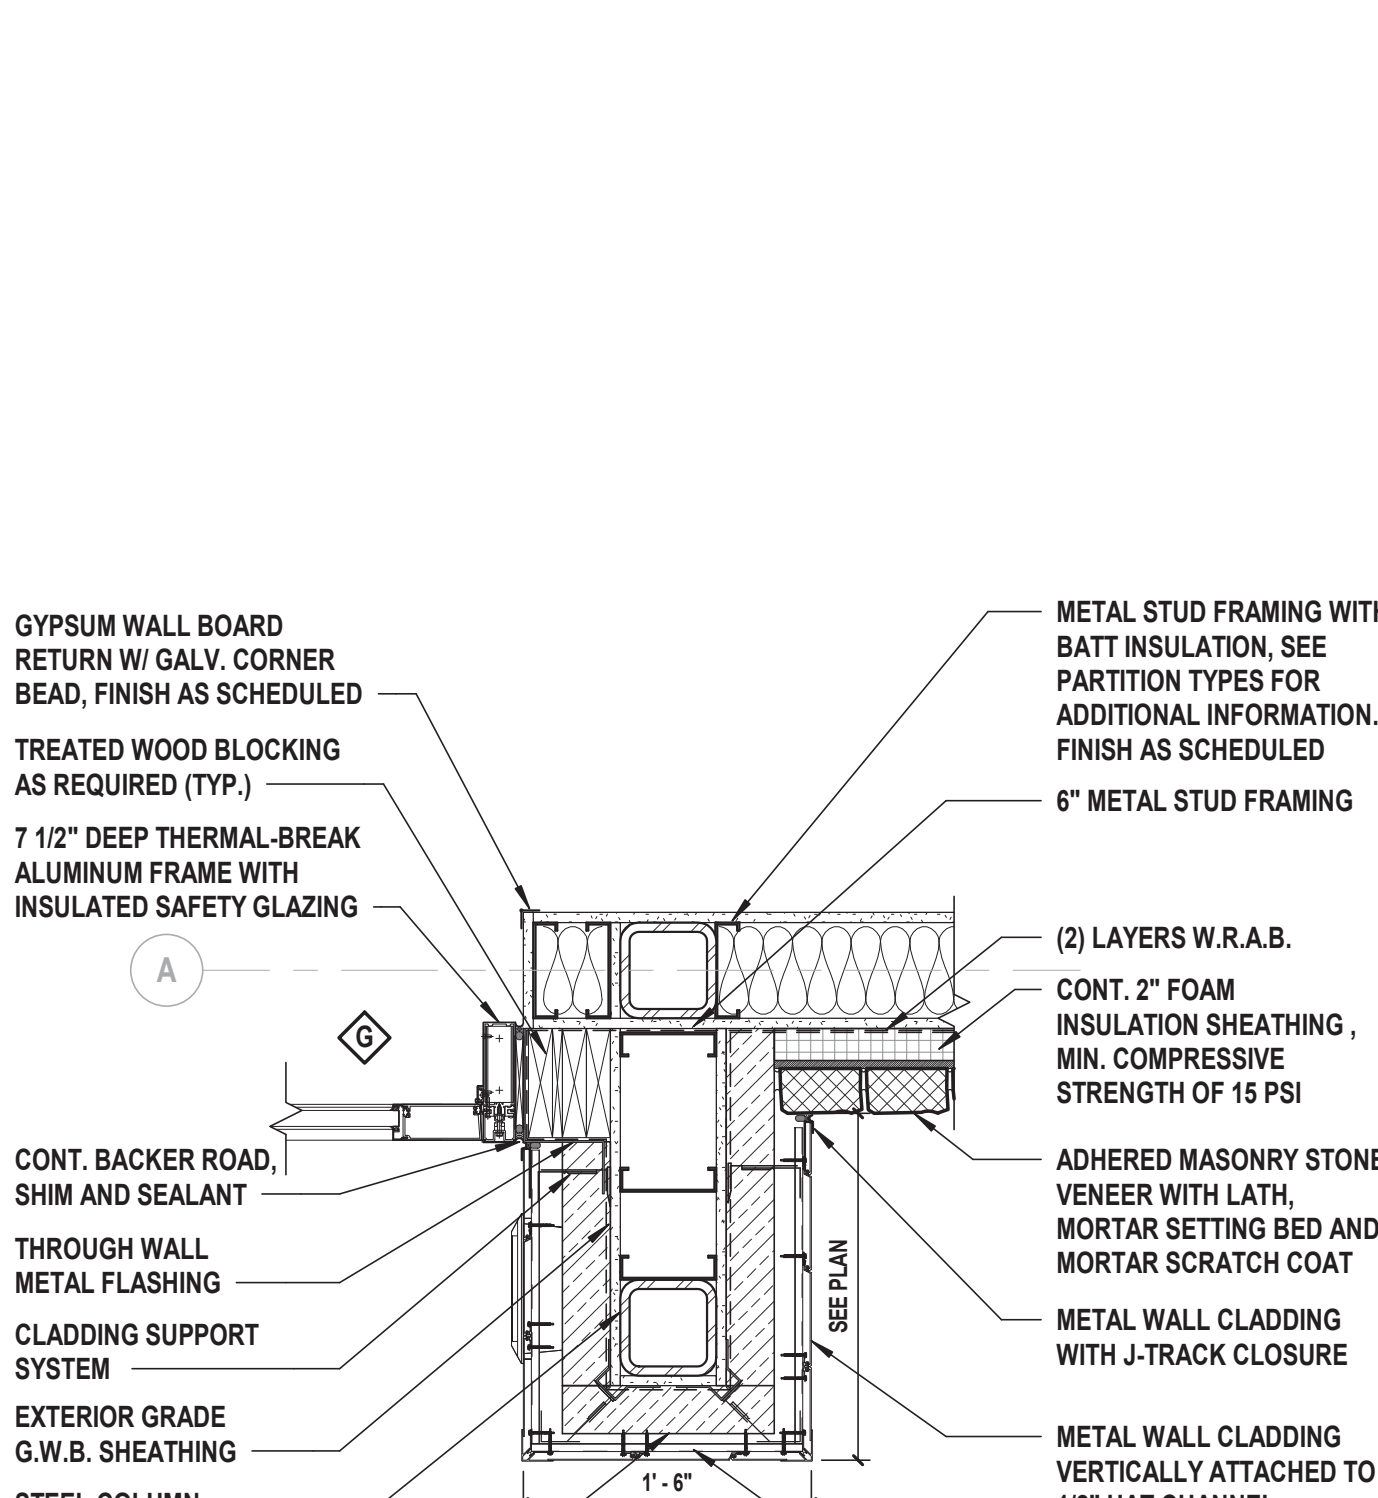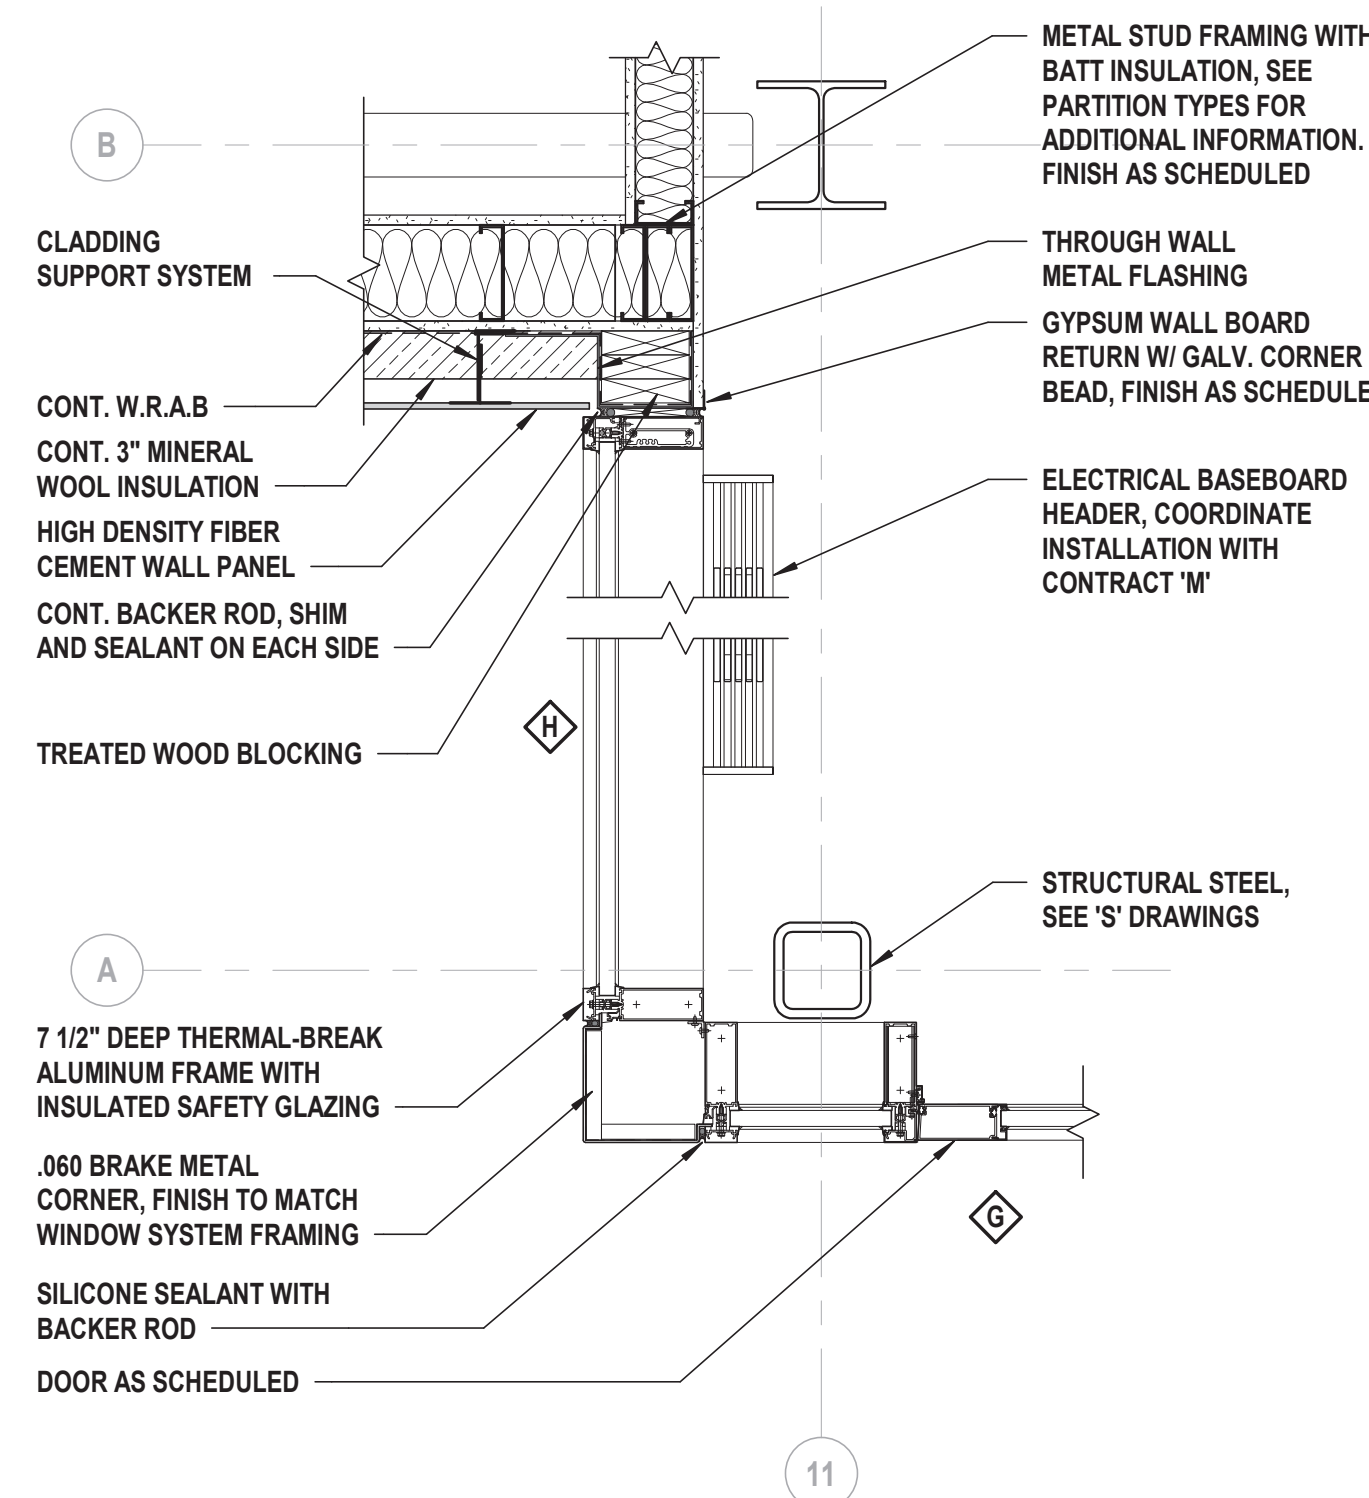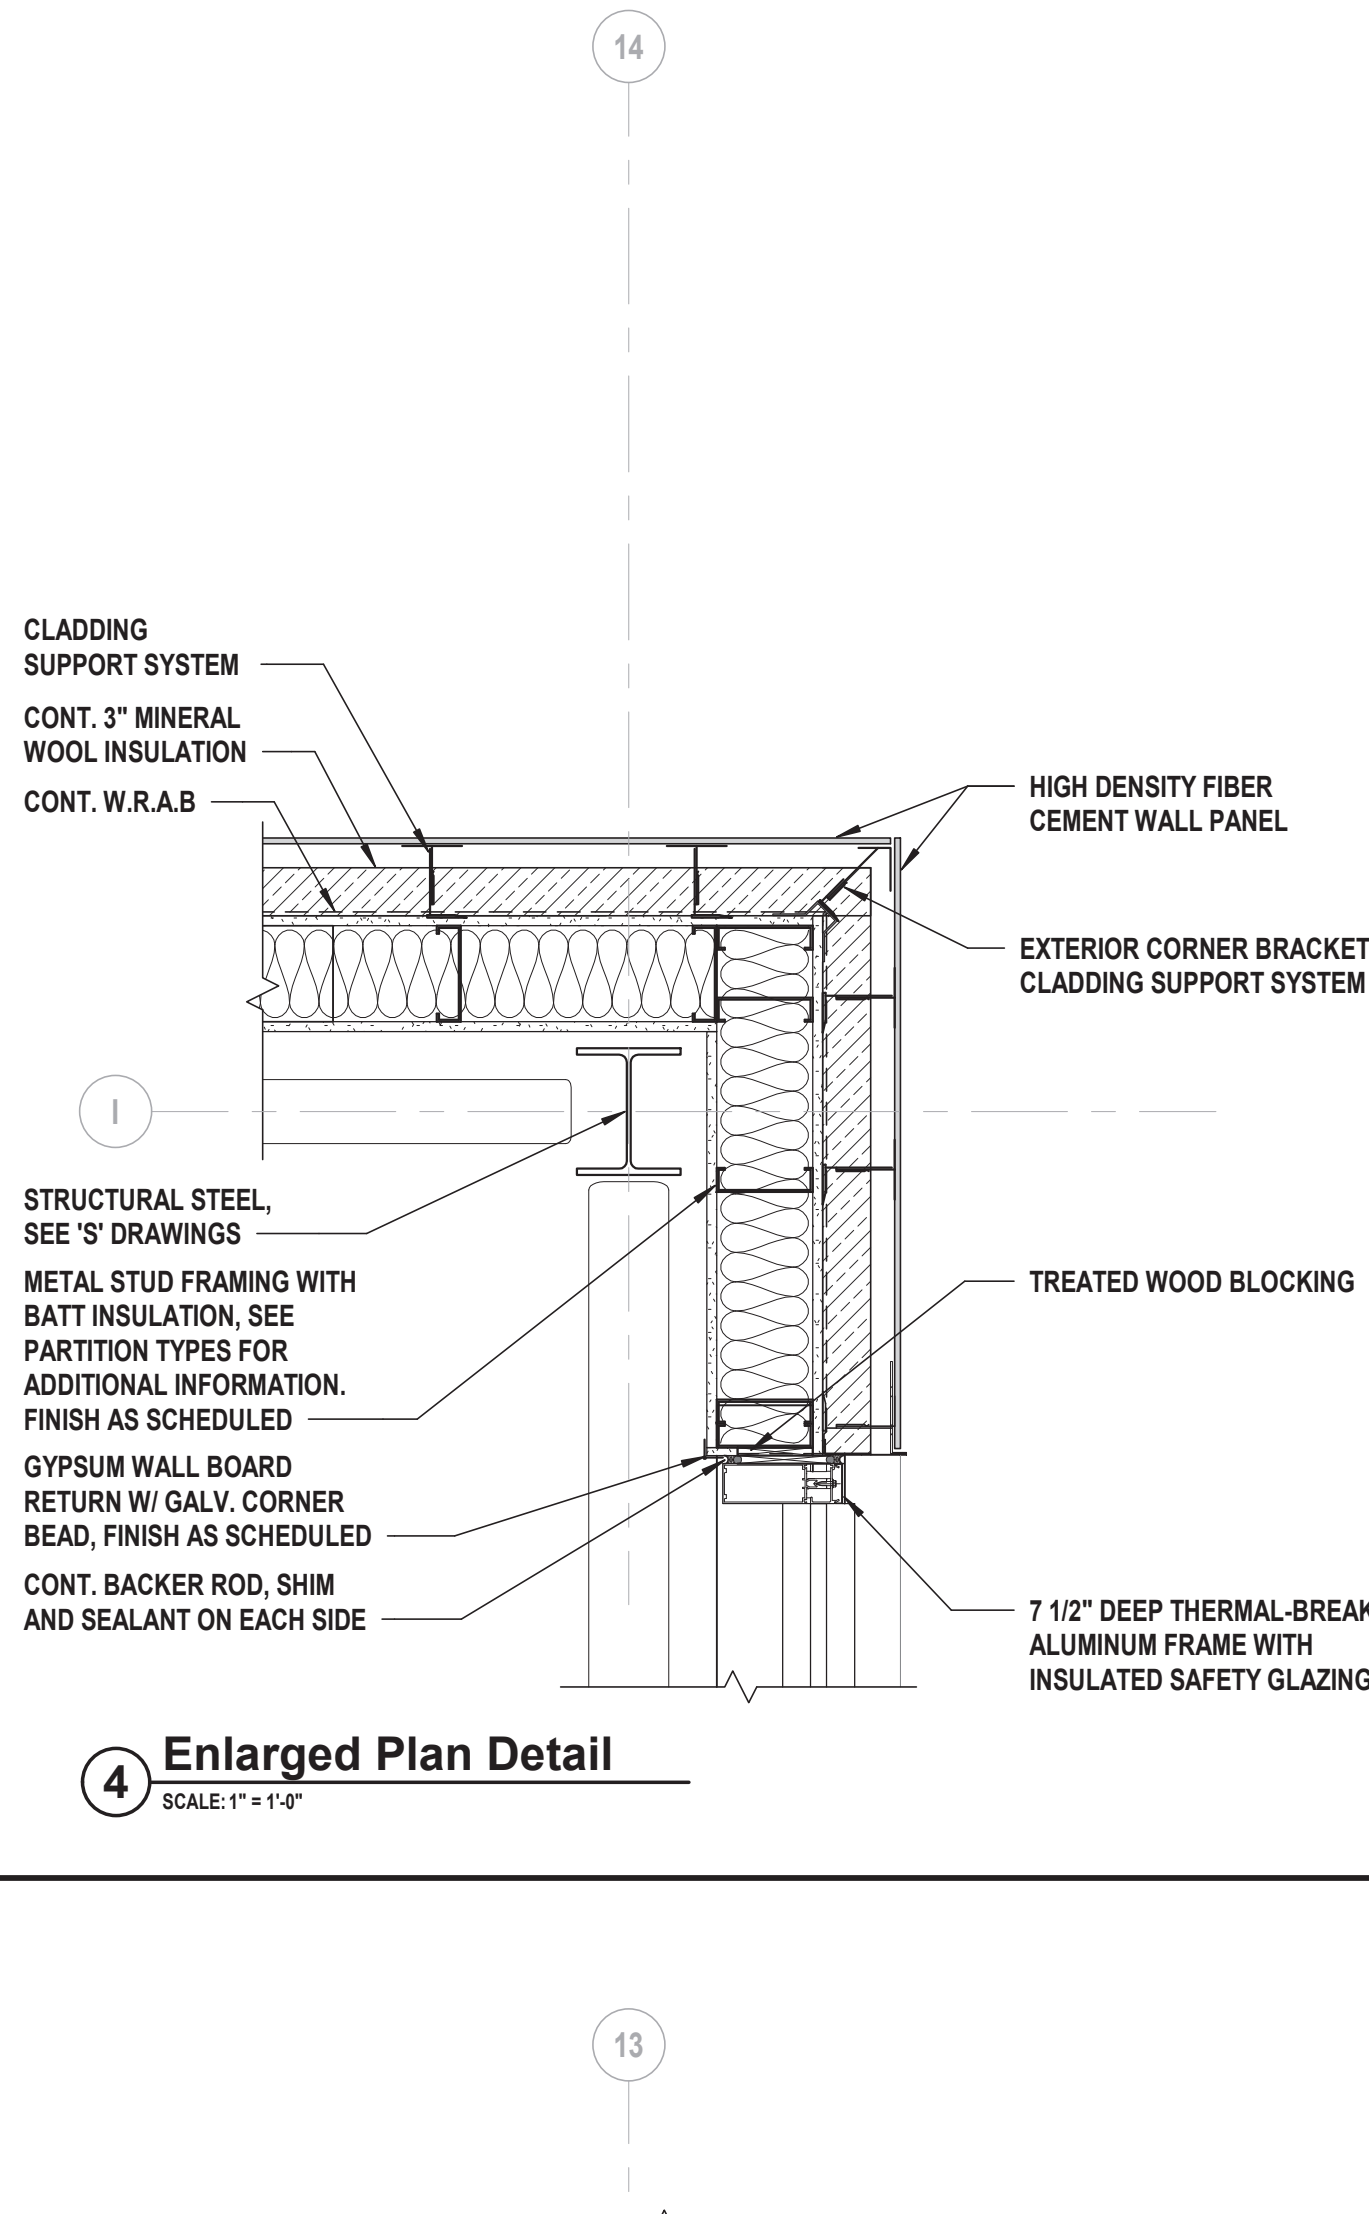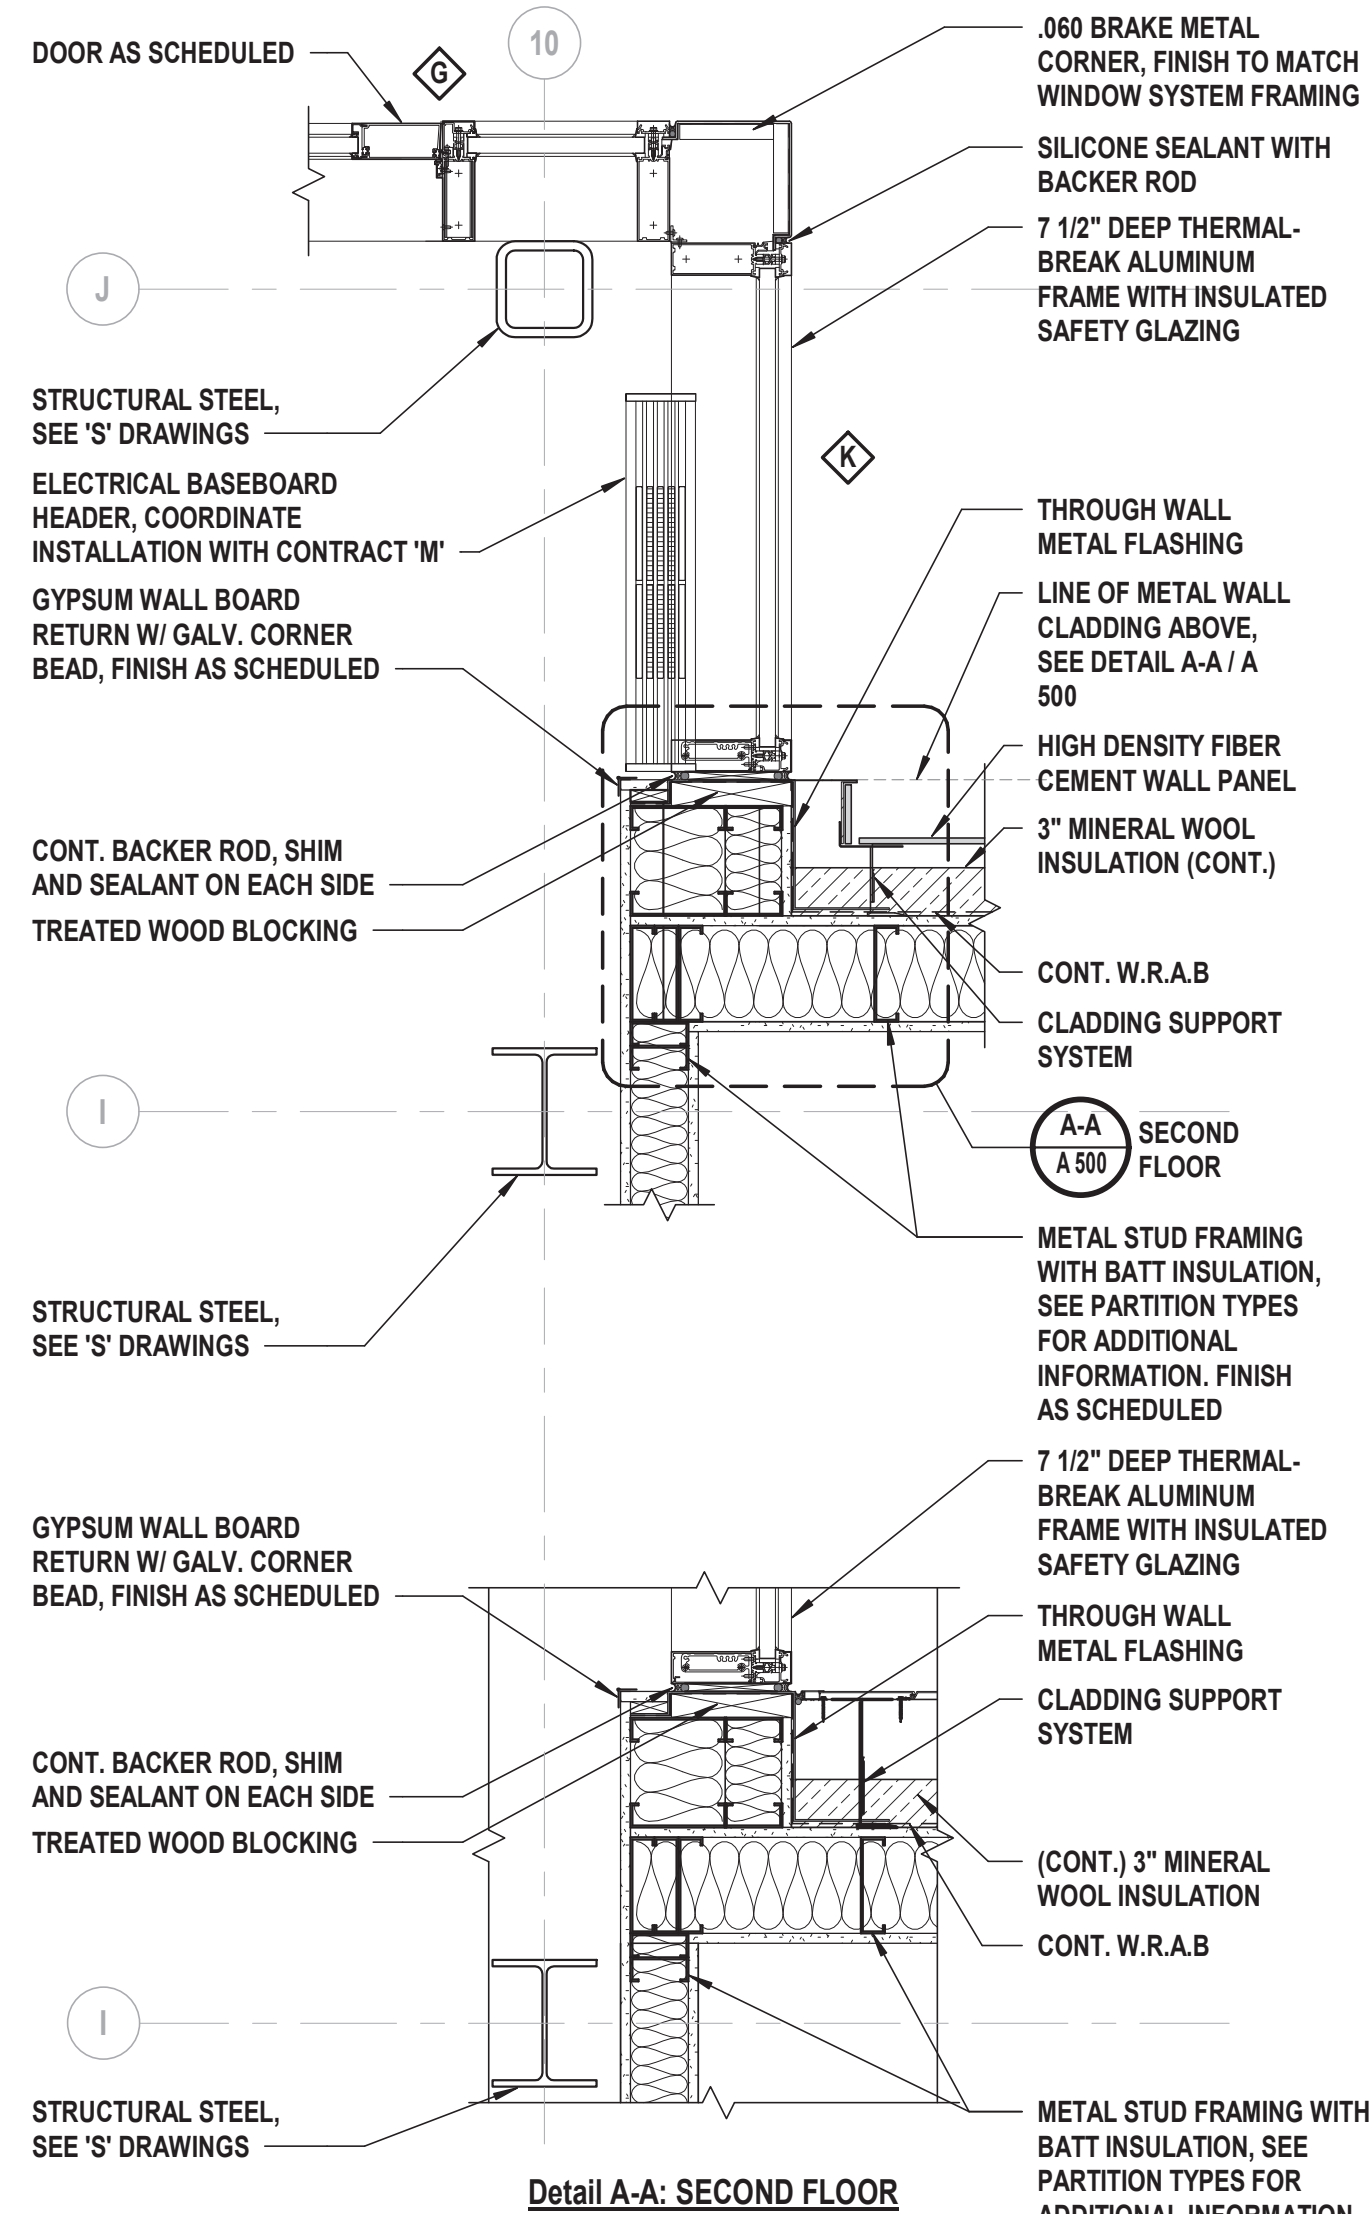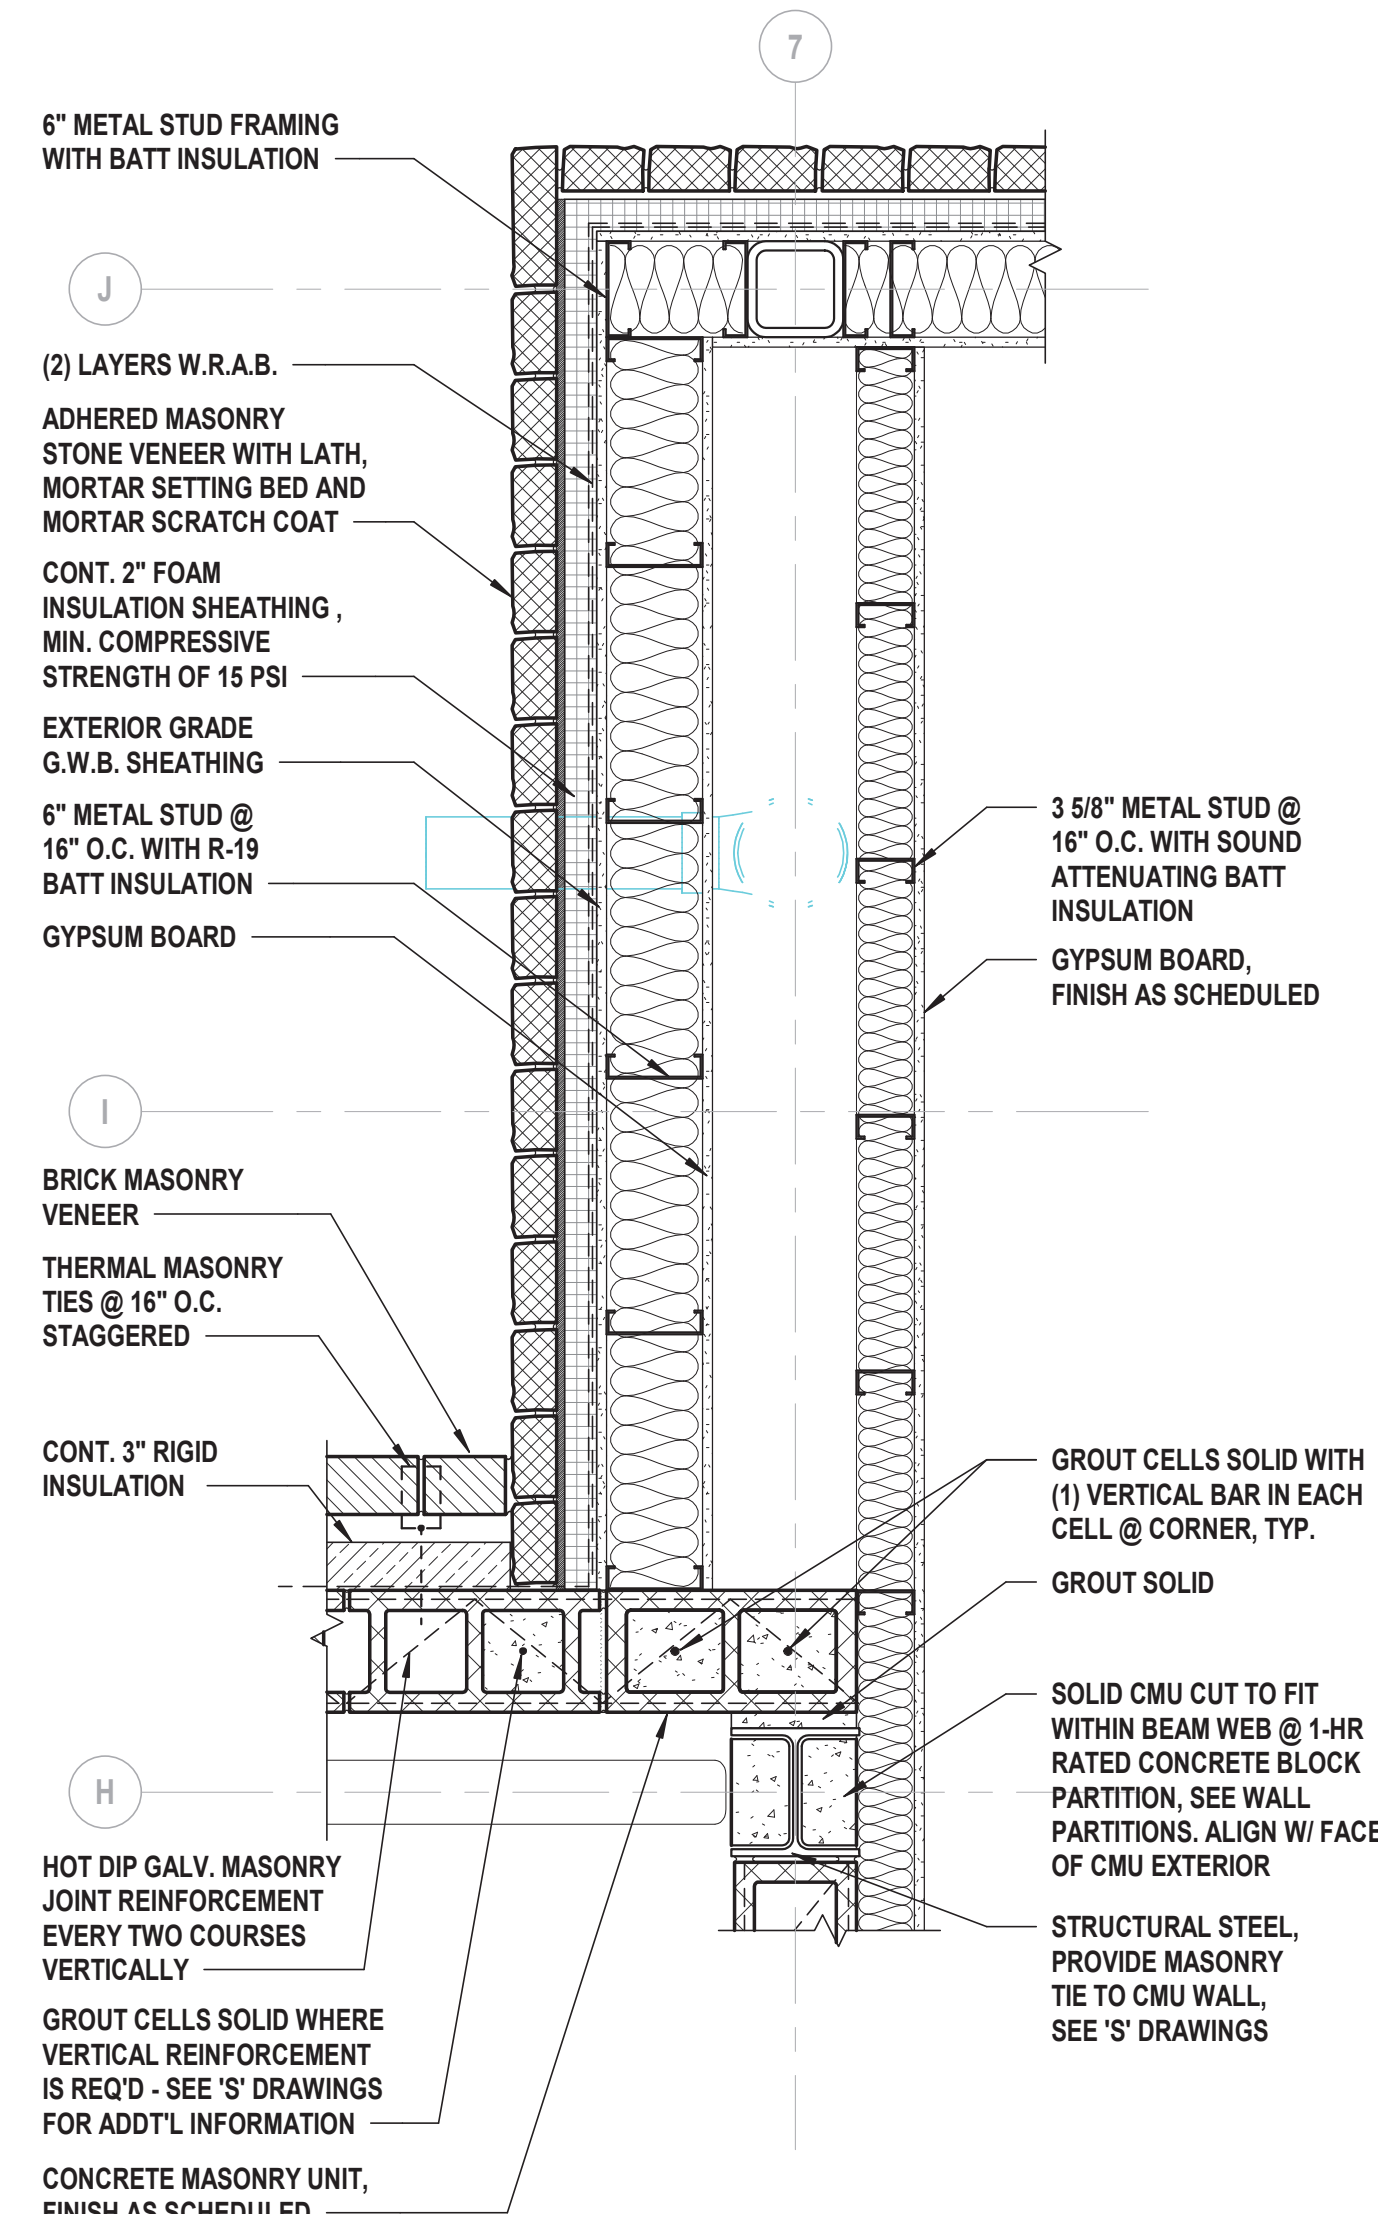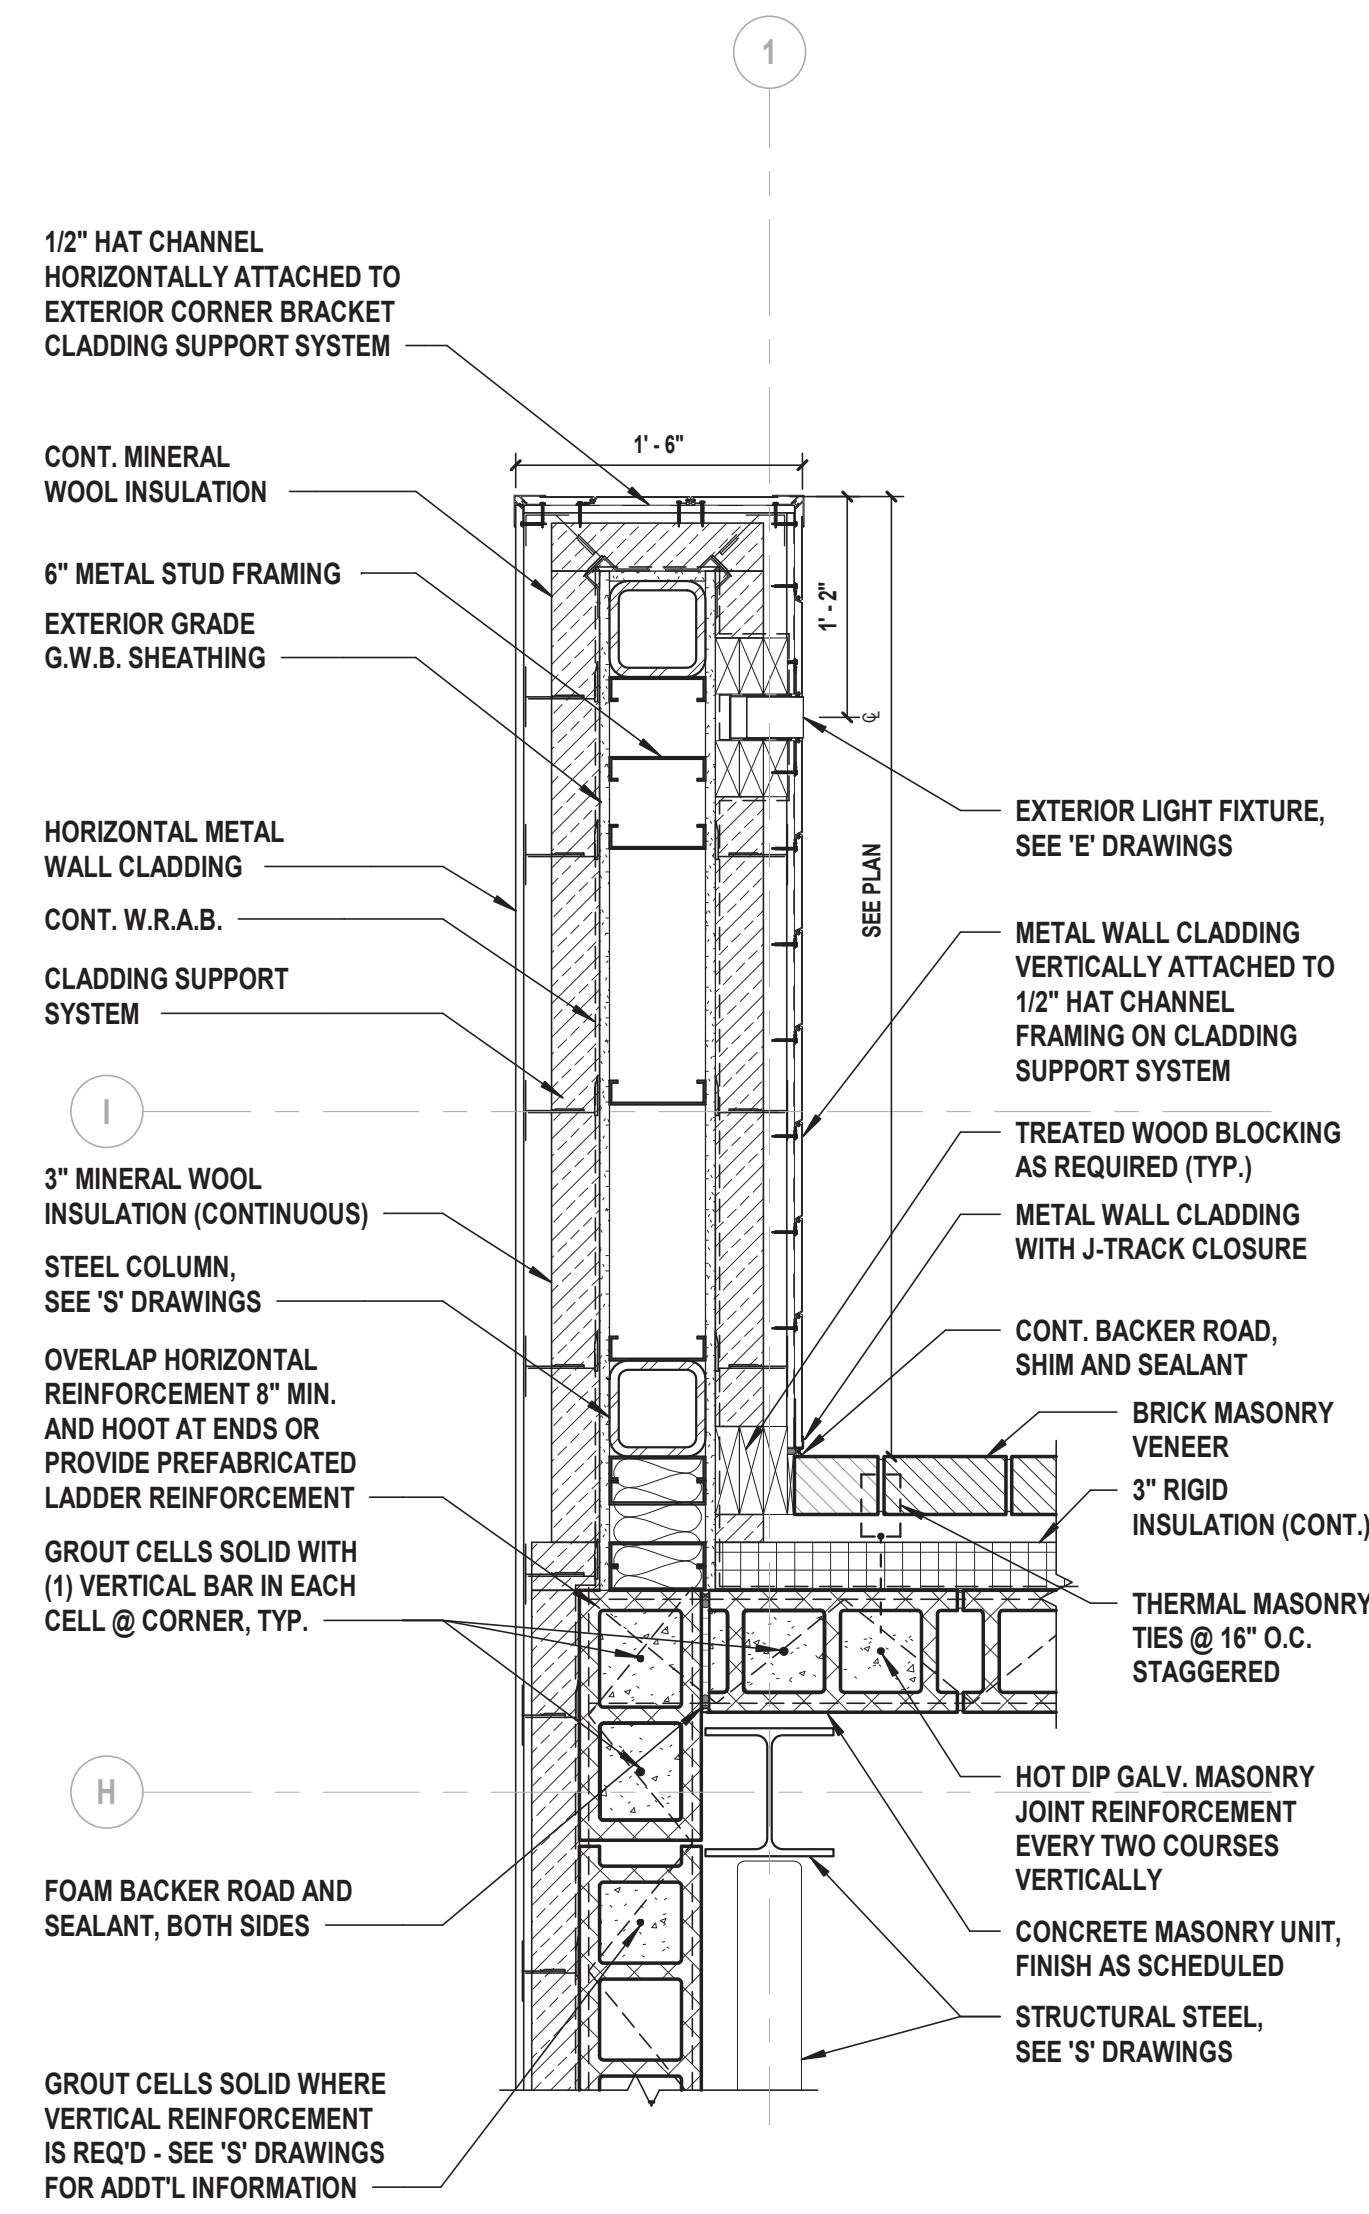

[illegible]

"IN ACCORDANCE WITH ARTICLE 140, SECTION 7209 OF THE NYS EDUCATION LAW, ALTERATION OF THIS DOCUMENT EXCEPT BY A LICENSED PROFESSIONAL IS ILLEGAL"			
DESIGNED BY: DBS/RLG	DRAWN BY: ANK	CHECKED BY: DBS	REVIEWED BY: POS
PROJECT No: TRFD 2302		DATE: FEBRUARY 2025	SCALE: AS SHOWN

**THIELLS
ROSEVILLE FIRE
DISTRICT**








65 W RAMAPO ROAD
GARNERVILLE, NY 10923

CONTRACT G
GENERAL CONSTRUCTION

FINAL BID DOCUMENT

SECTION DETAILS

A 501.00

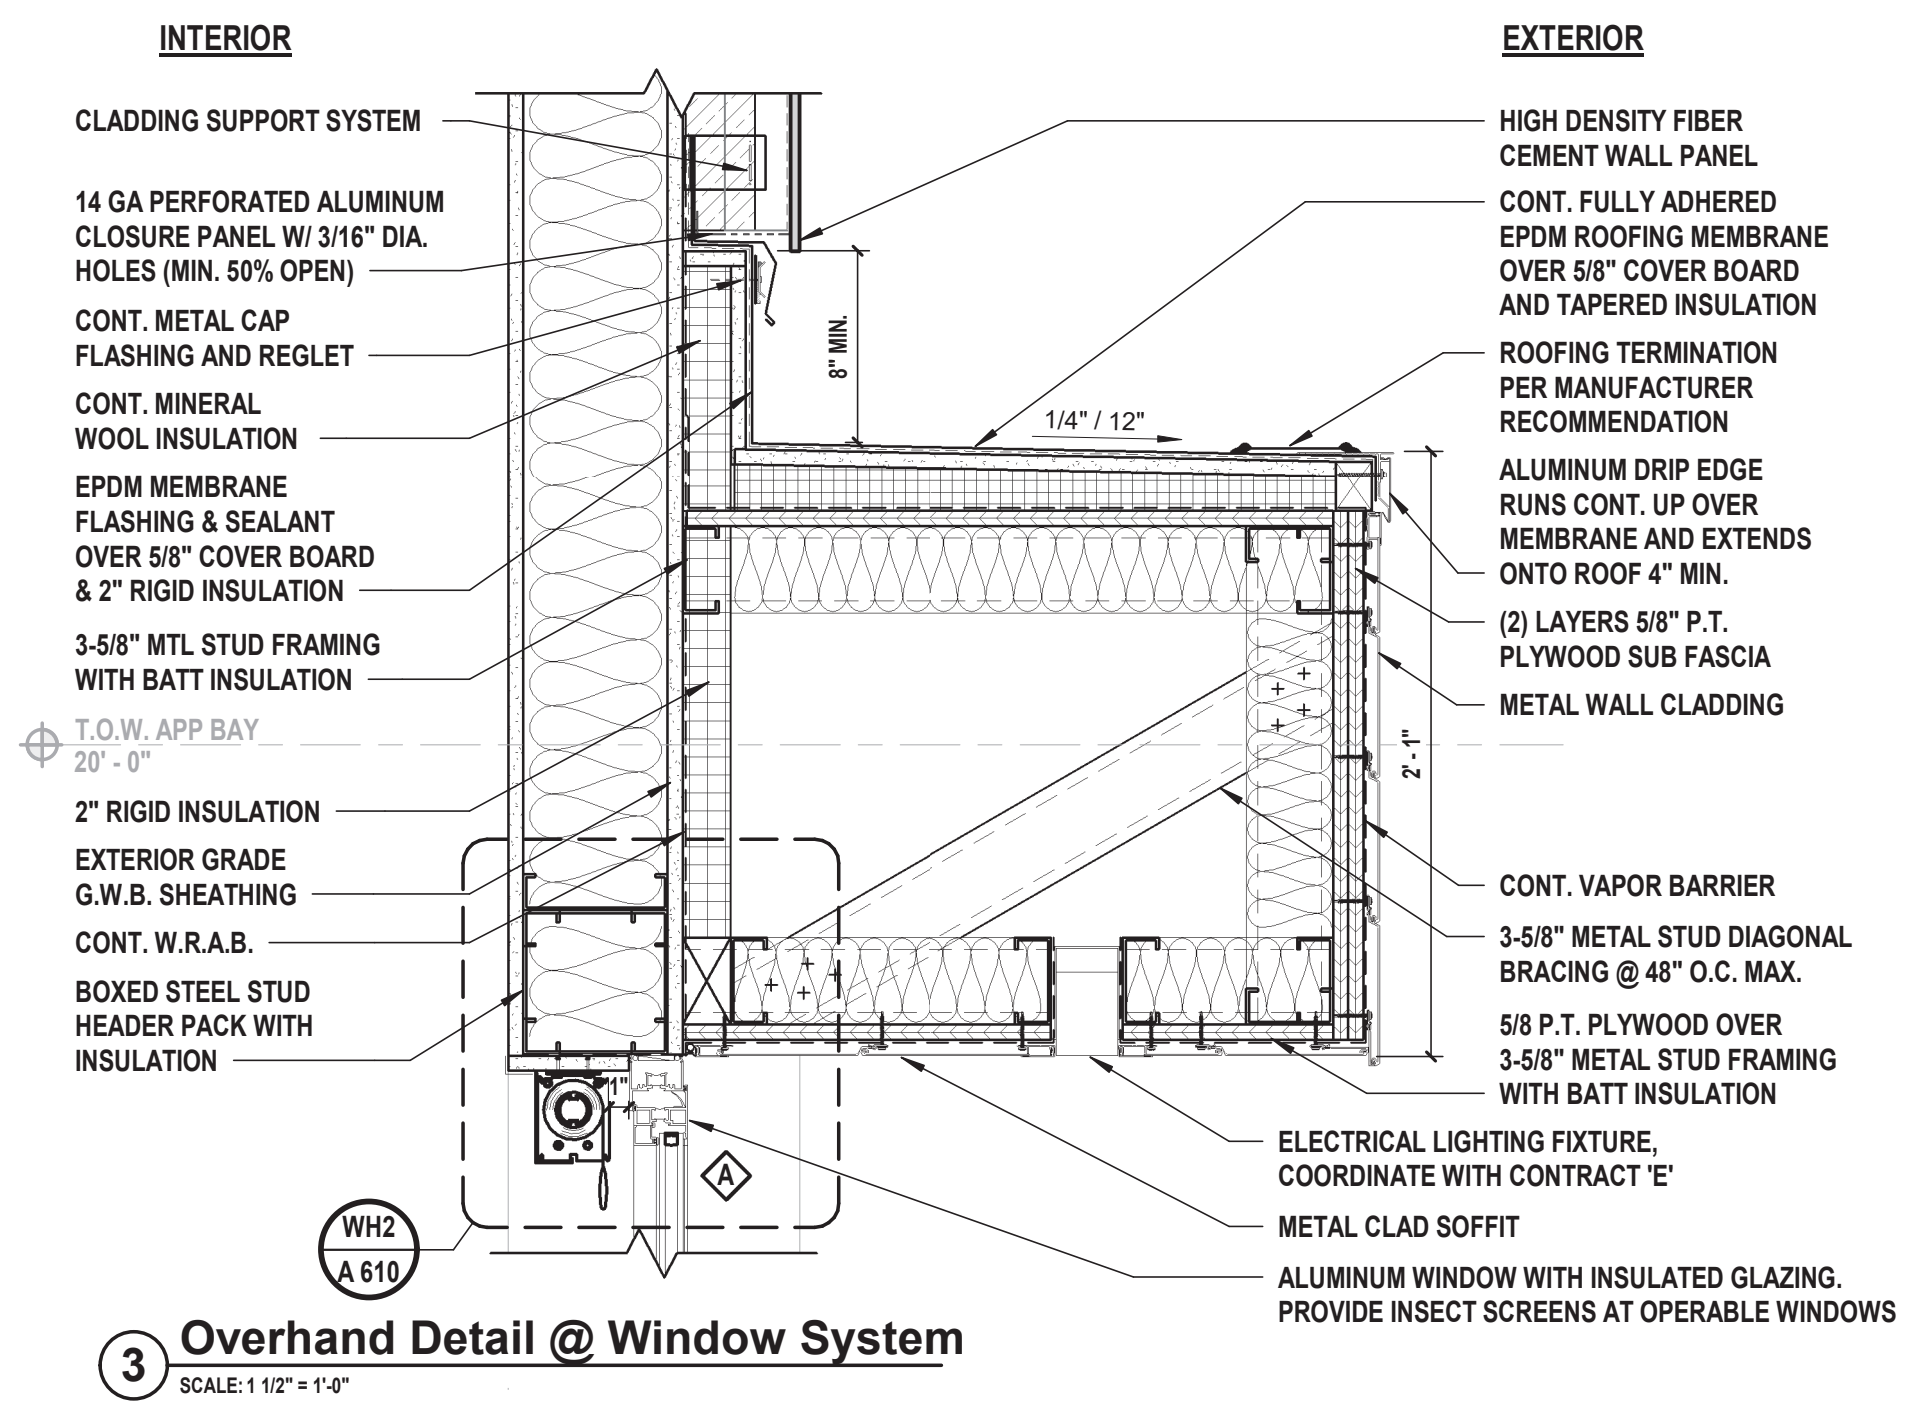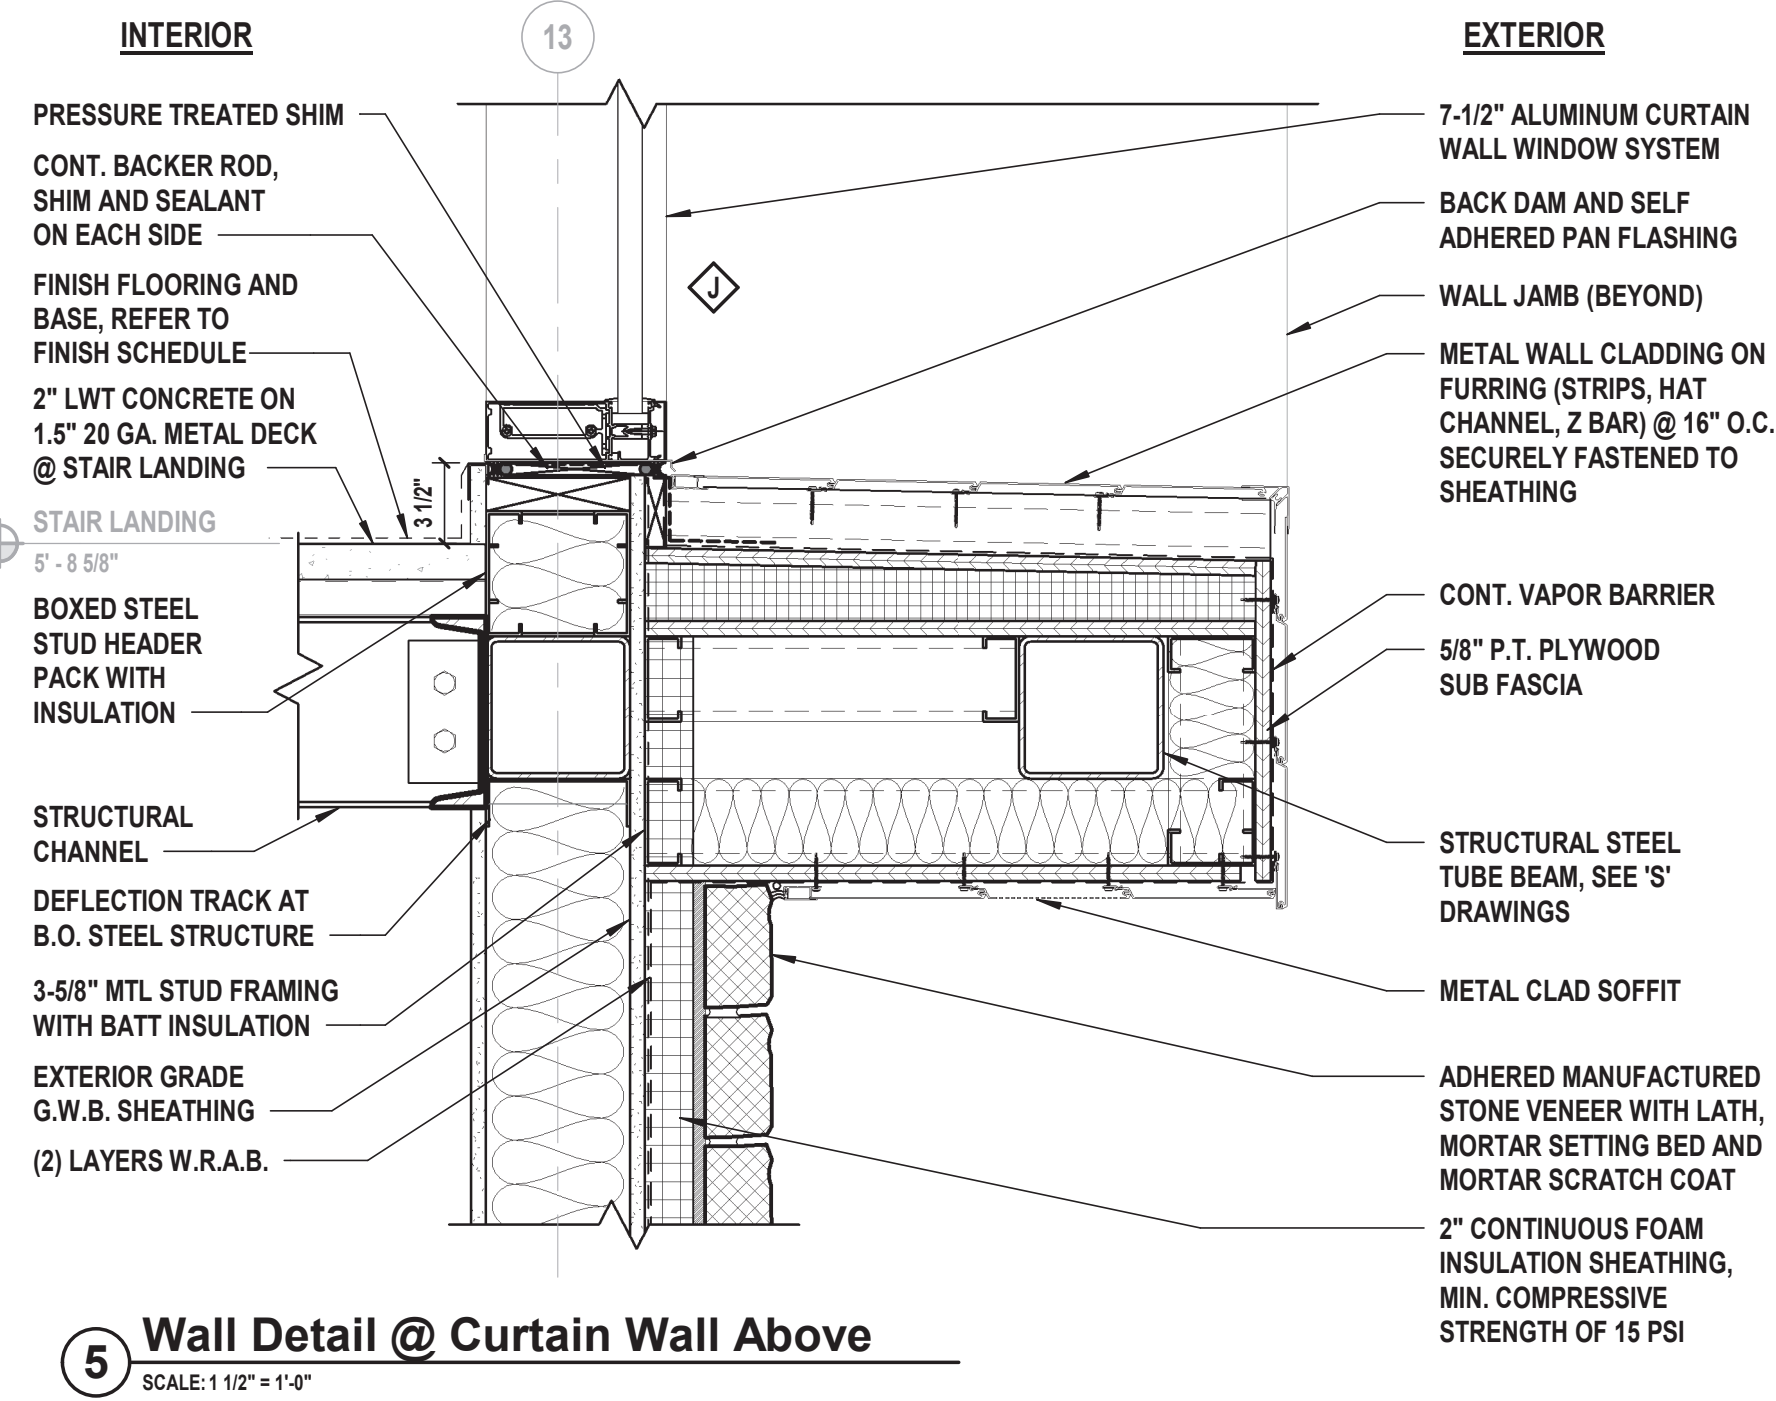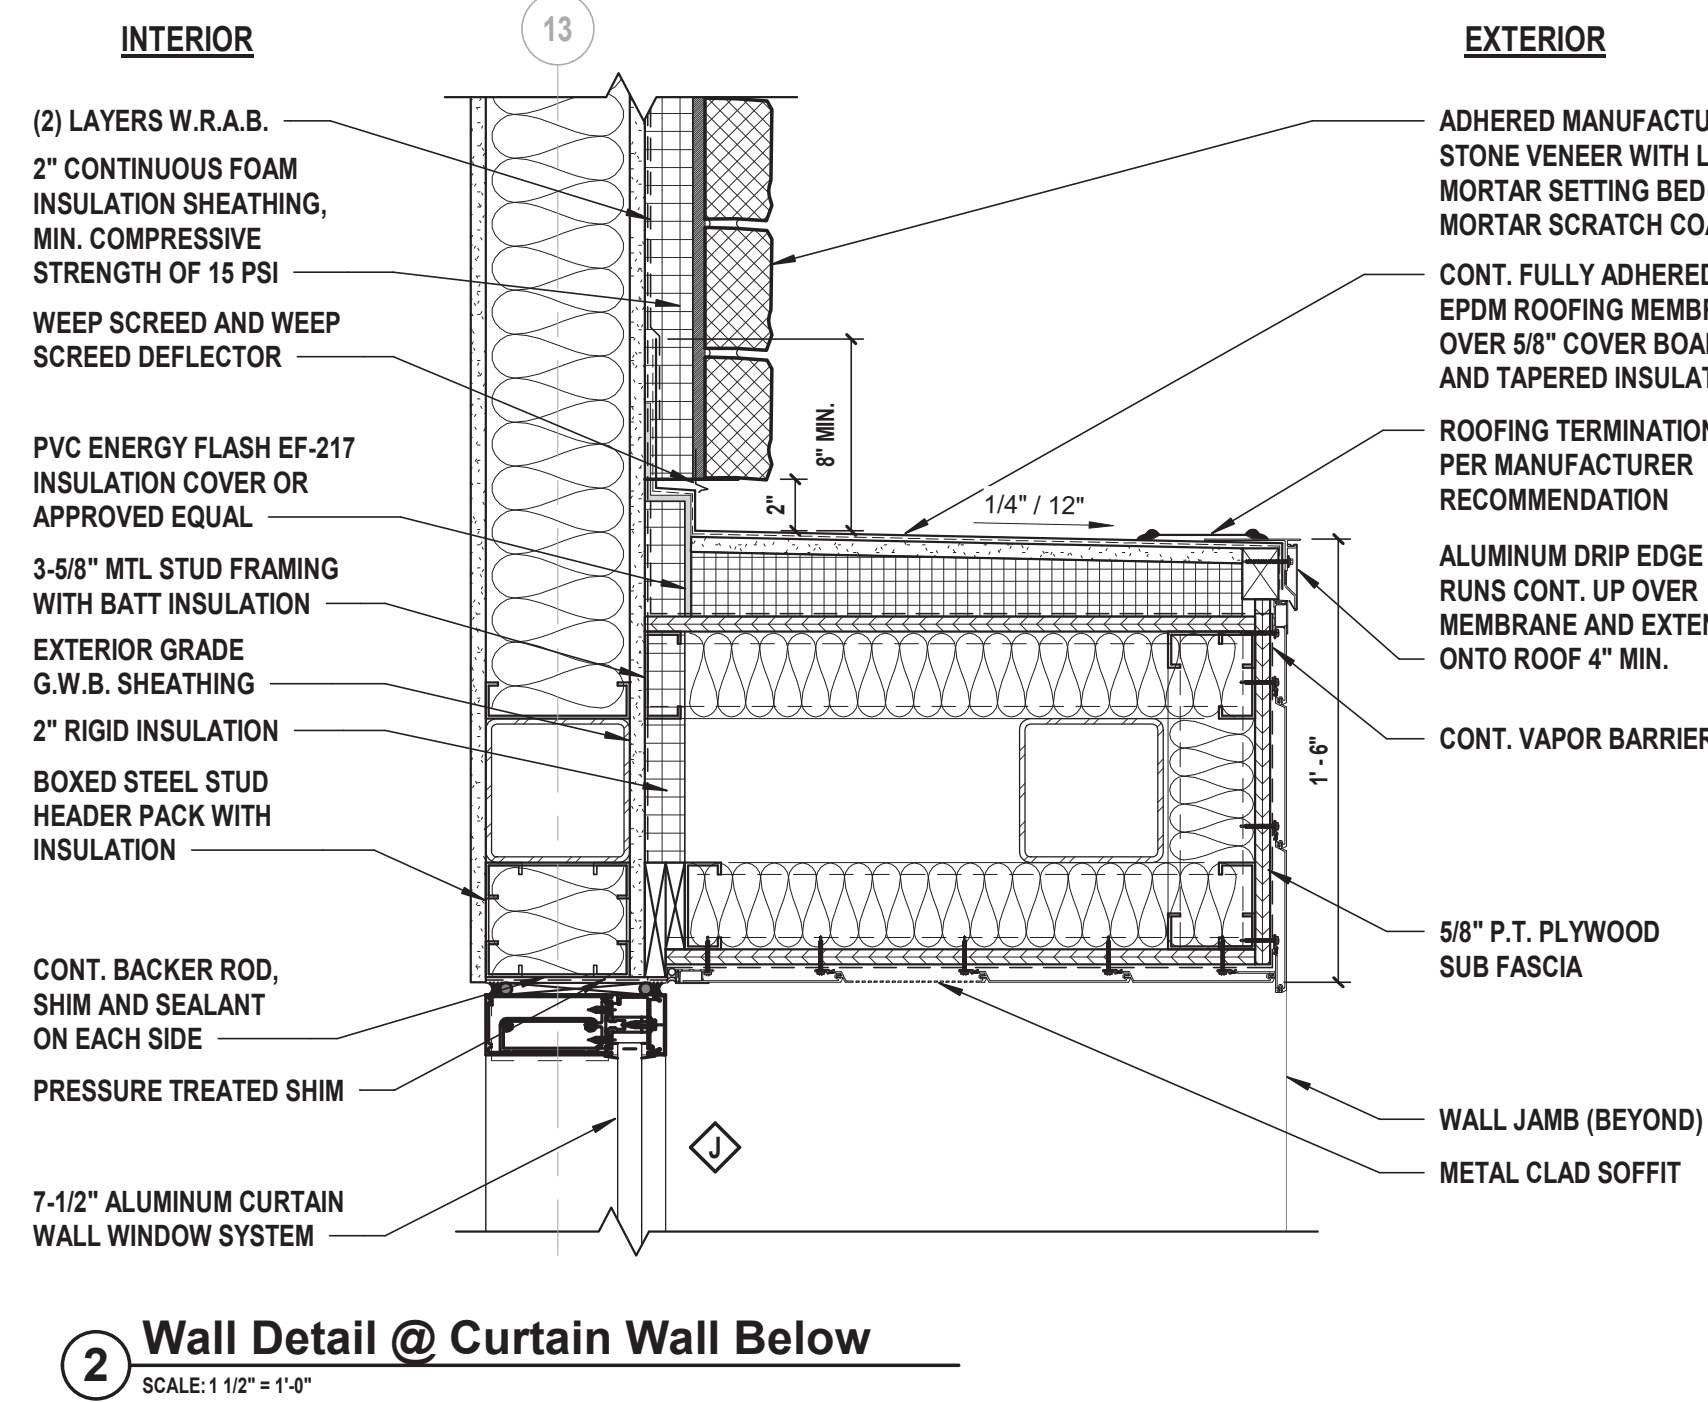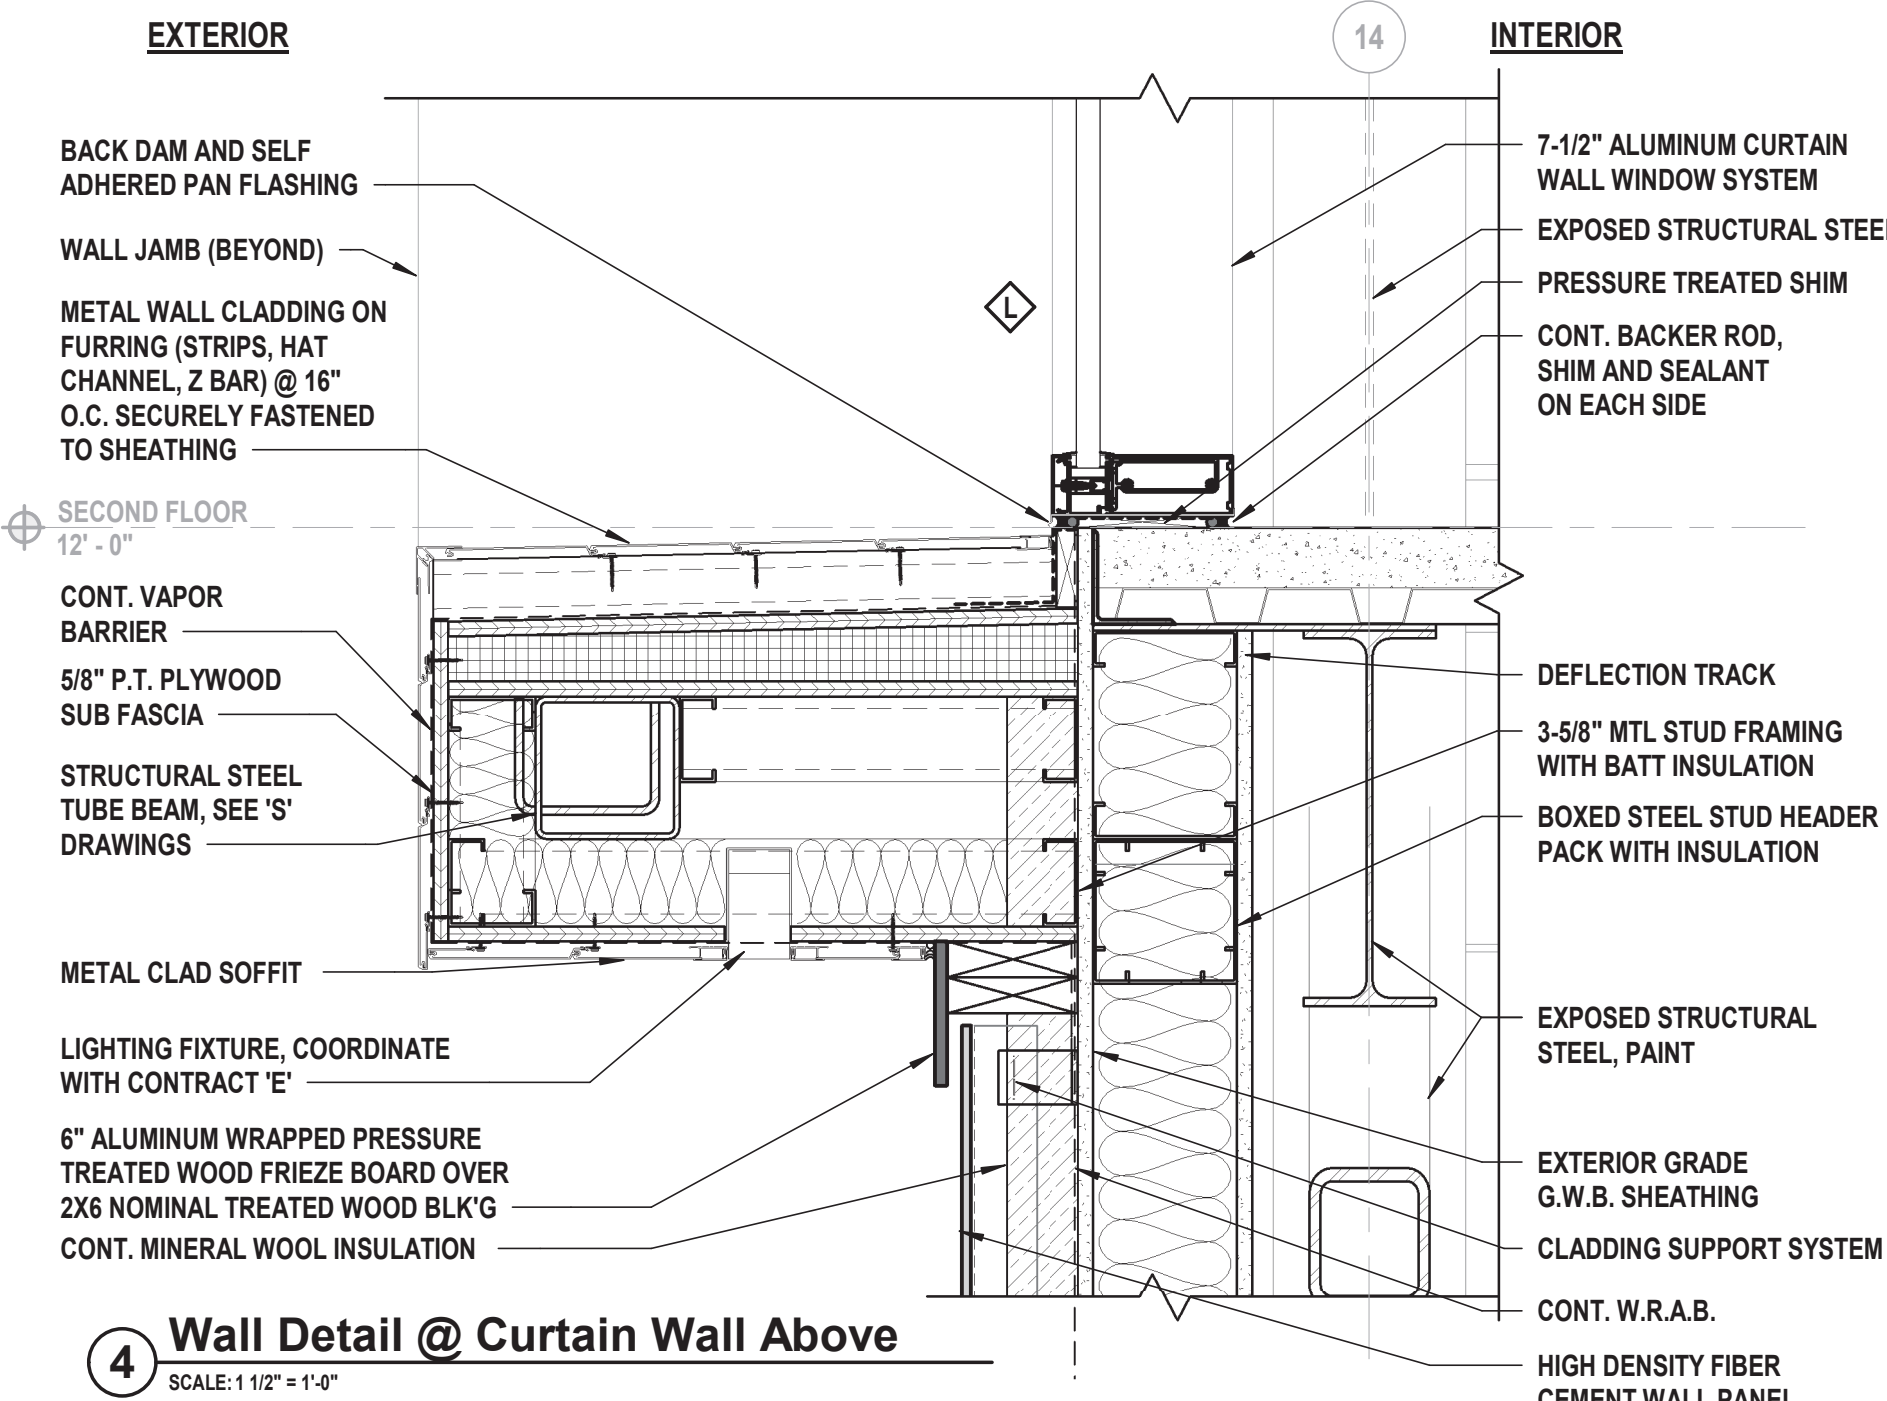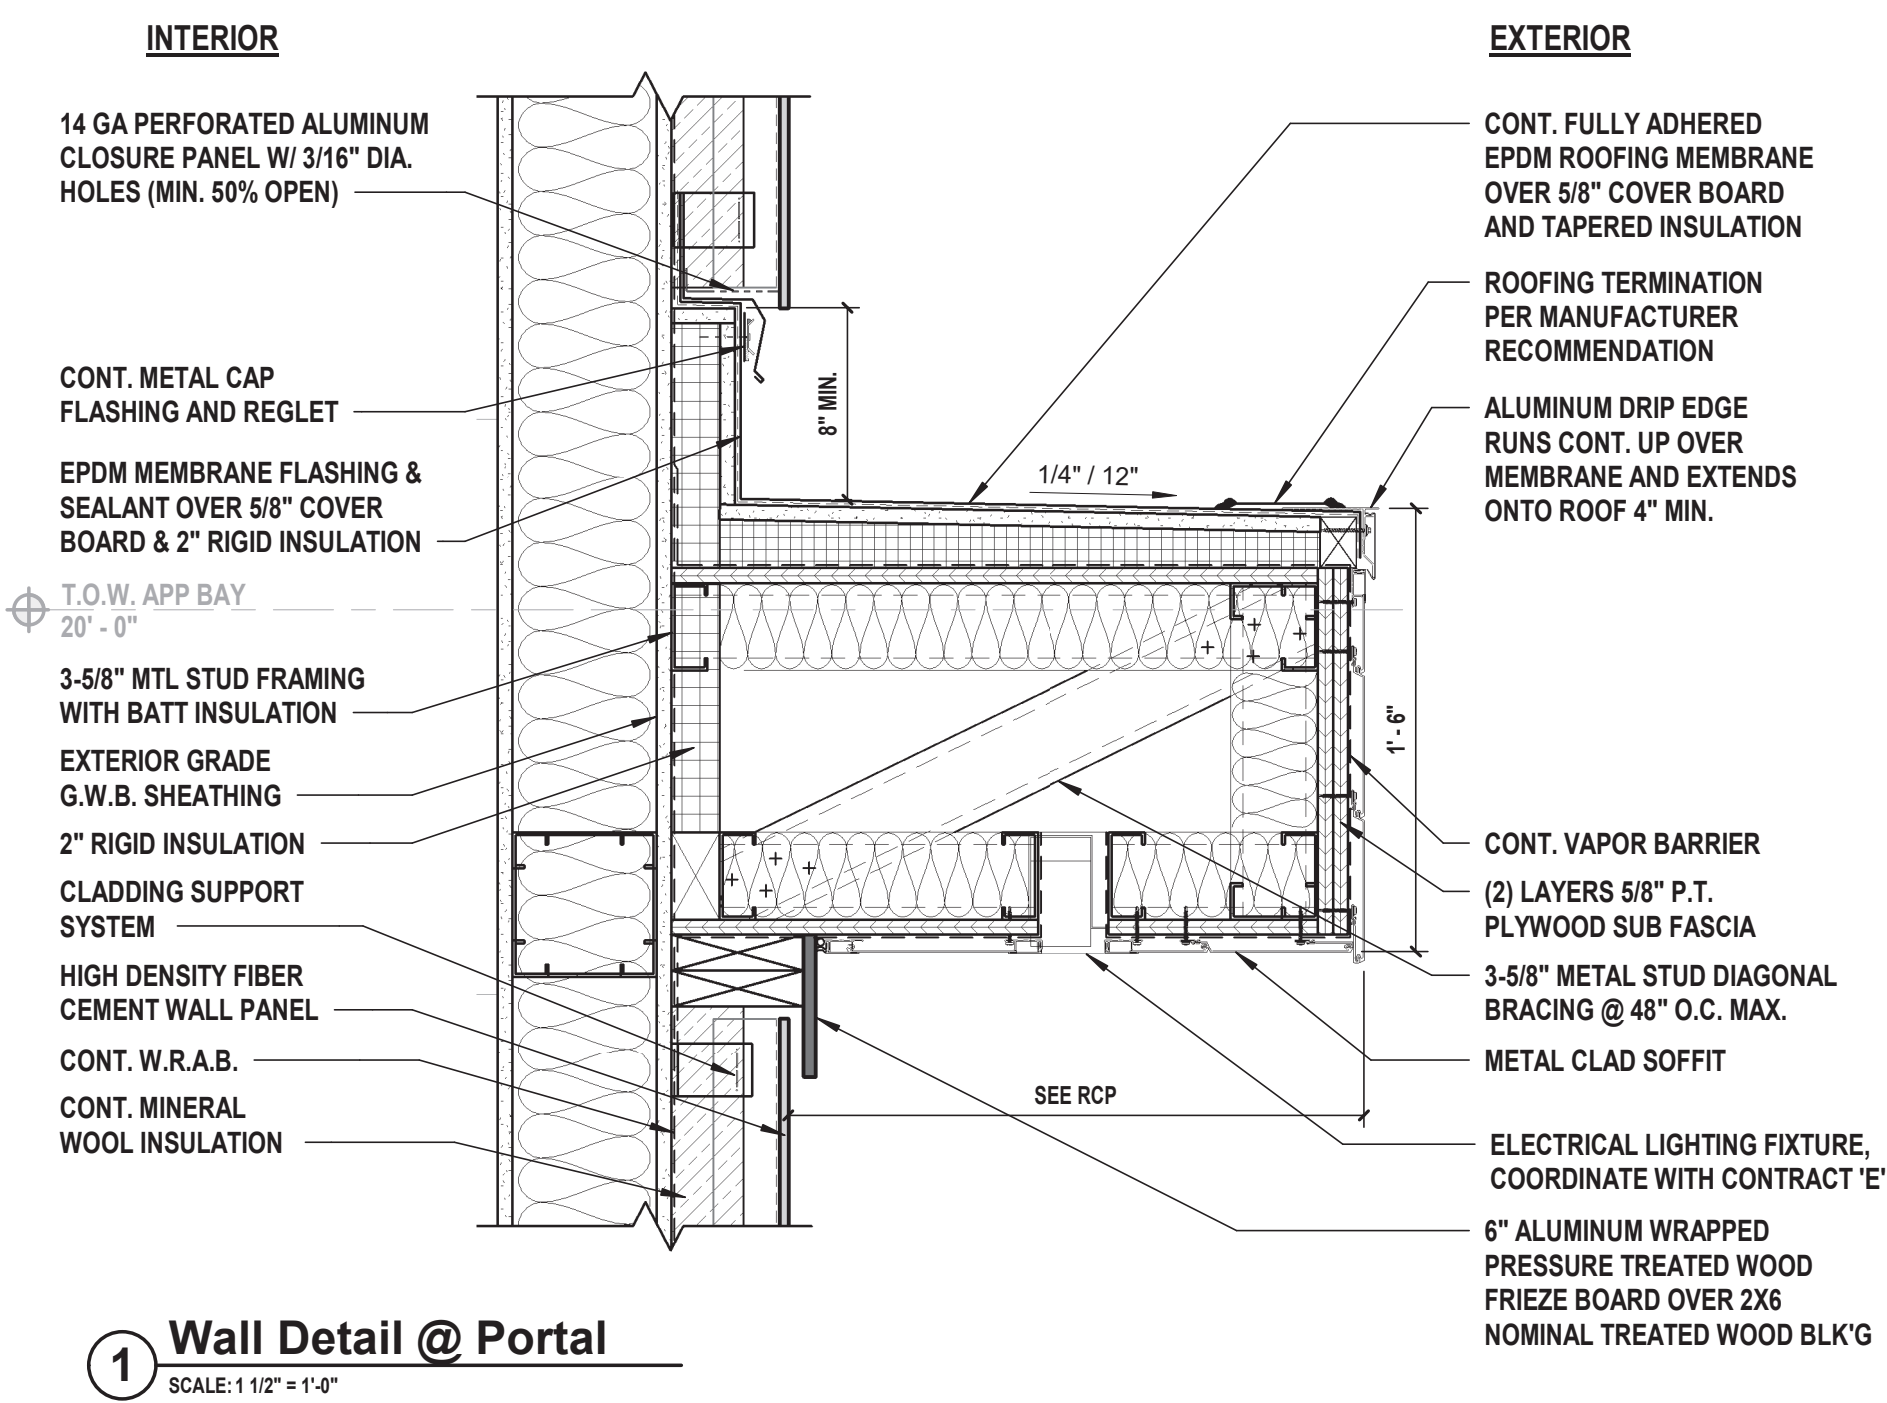

CONSULTANTS:		

MARK	DATE	DESCRIPTION

REGISTERED ARCHITECT
PATRICK O. STONE
STATE OF NEW YORK
029654

10/31/2025

Exp. Date

PATRICK O. STONE, R.A.

NY PROFESSIONAL ARCHITECT LIC. NO. 029654

DESIGNED BY: DBS/RLG

DRAWN BY: ANK

CHECKED BY: DBS

REVIEWED BY: POS

PROJECT No: TRFD 2302

DATE: FEBRUARY 2025

SCALE: AS SHOWN

IN ACCORDANCE WITH ARTICLE 145, SECTION 1209 OF THE NYS EDUCATION LAW,
ALTACTION OF THIS DOCUMENT EXCEPT BY A LICENSED PROFESSIONAL IS ILLEGAL.

CLIENT

THIELLS
ROSEVILLE FIRE
DISTRICT

NEW 26-100 FIRE
HEADQUARTERS

THIELLS

26

FD

65 W RAMAPO ROAD
GARNERVILLE, NY 10923

CONTRACT

CONTRACT G
GENERAL CONSTRUCTION

STATUS


FINAL BID DOCUMENT

SHEET TITLE


INTERIOR DETAILS

DRAWING No.


A 502.00

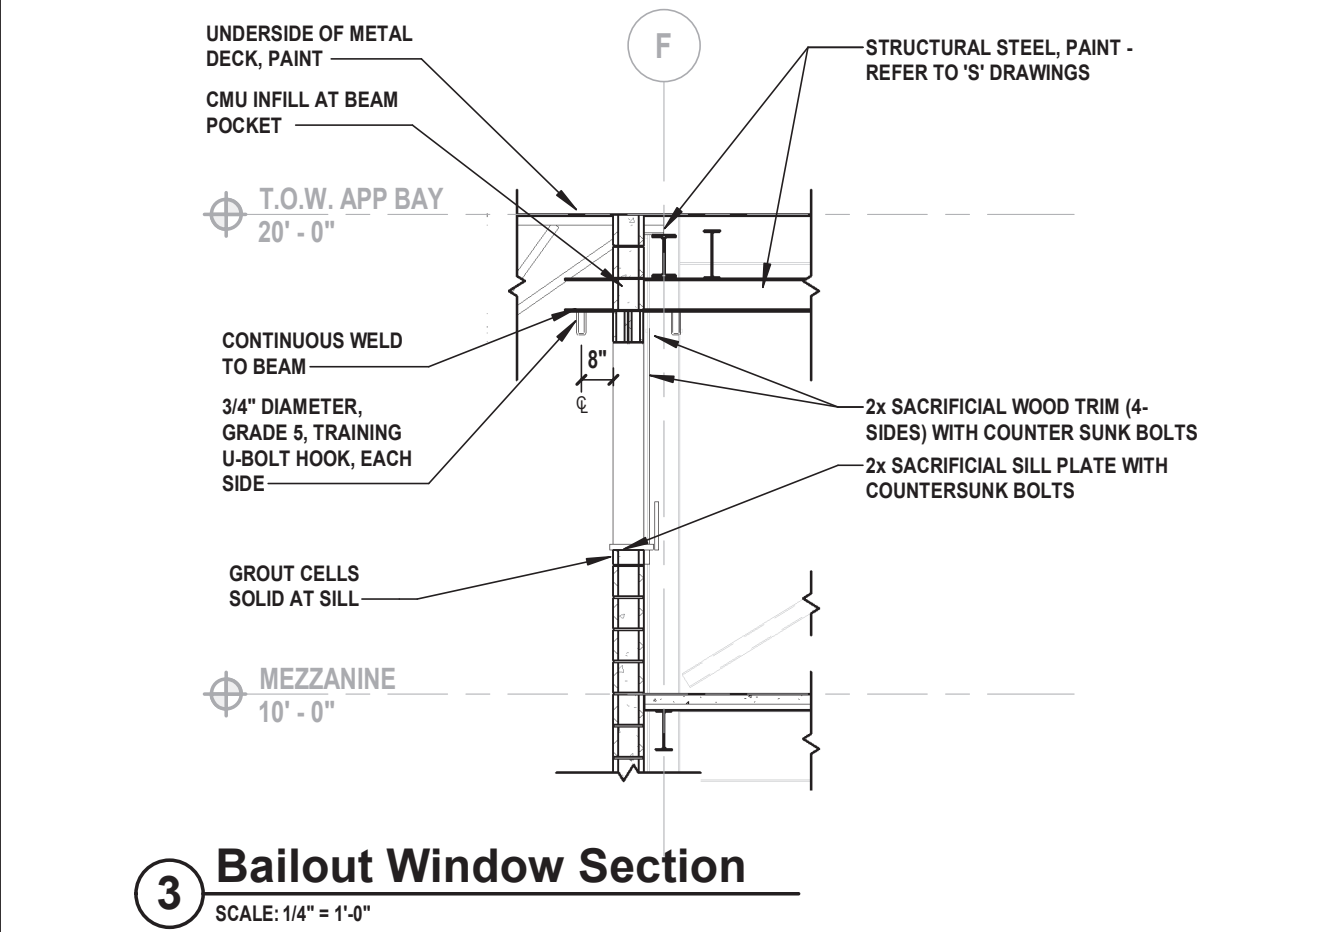


3 Bailout Window Section
SCALE: 1/4" = 1'-0"

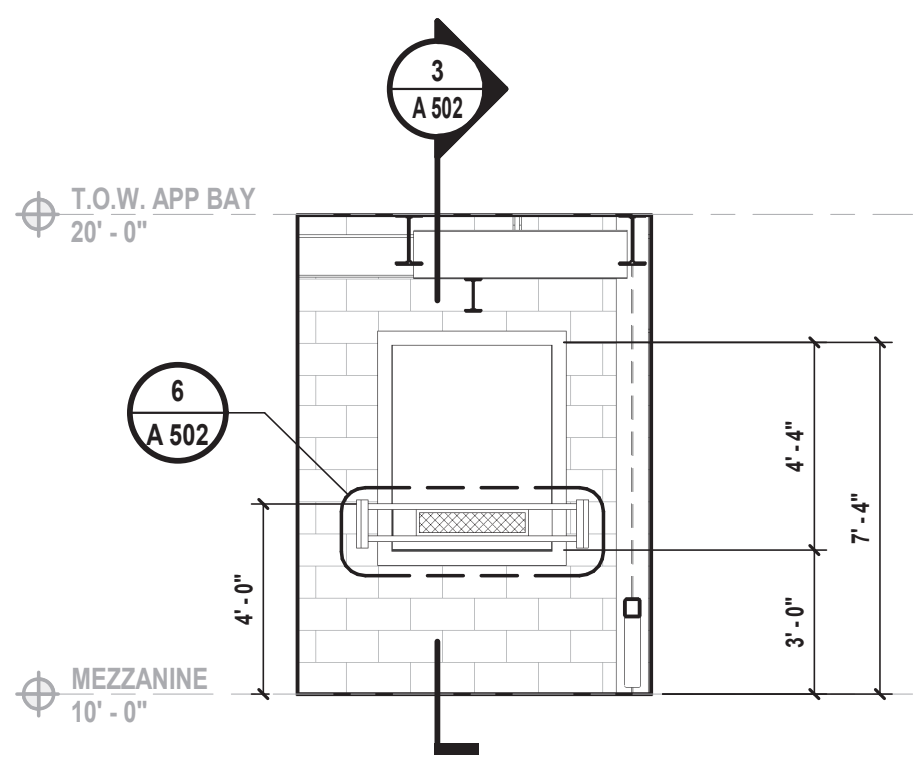


2 Interior Elevation - Bailout Window
SCALE: 1/4" = 1'-0"

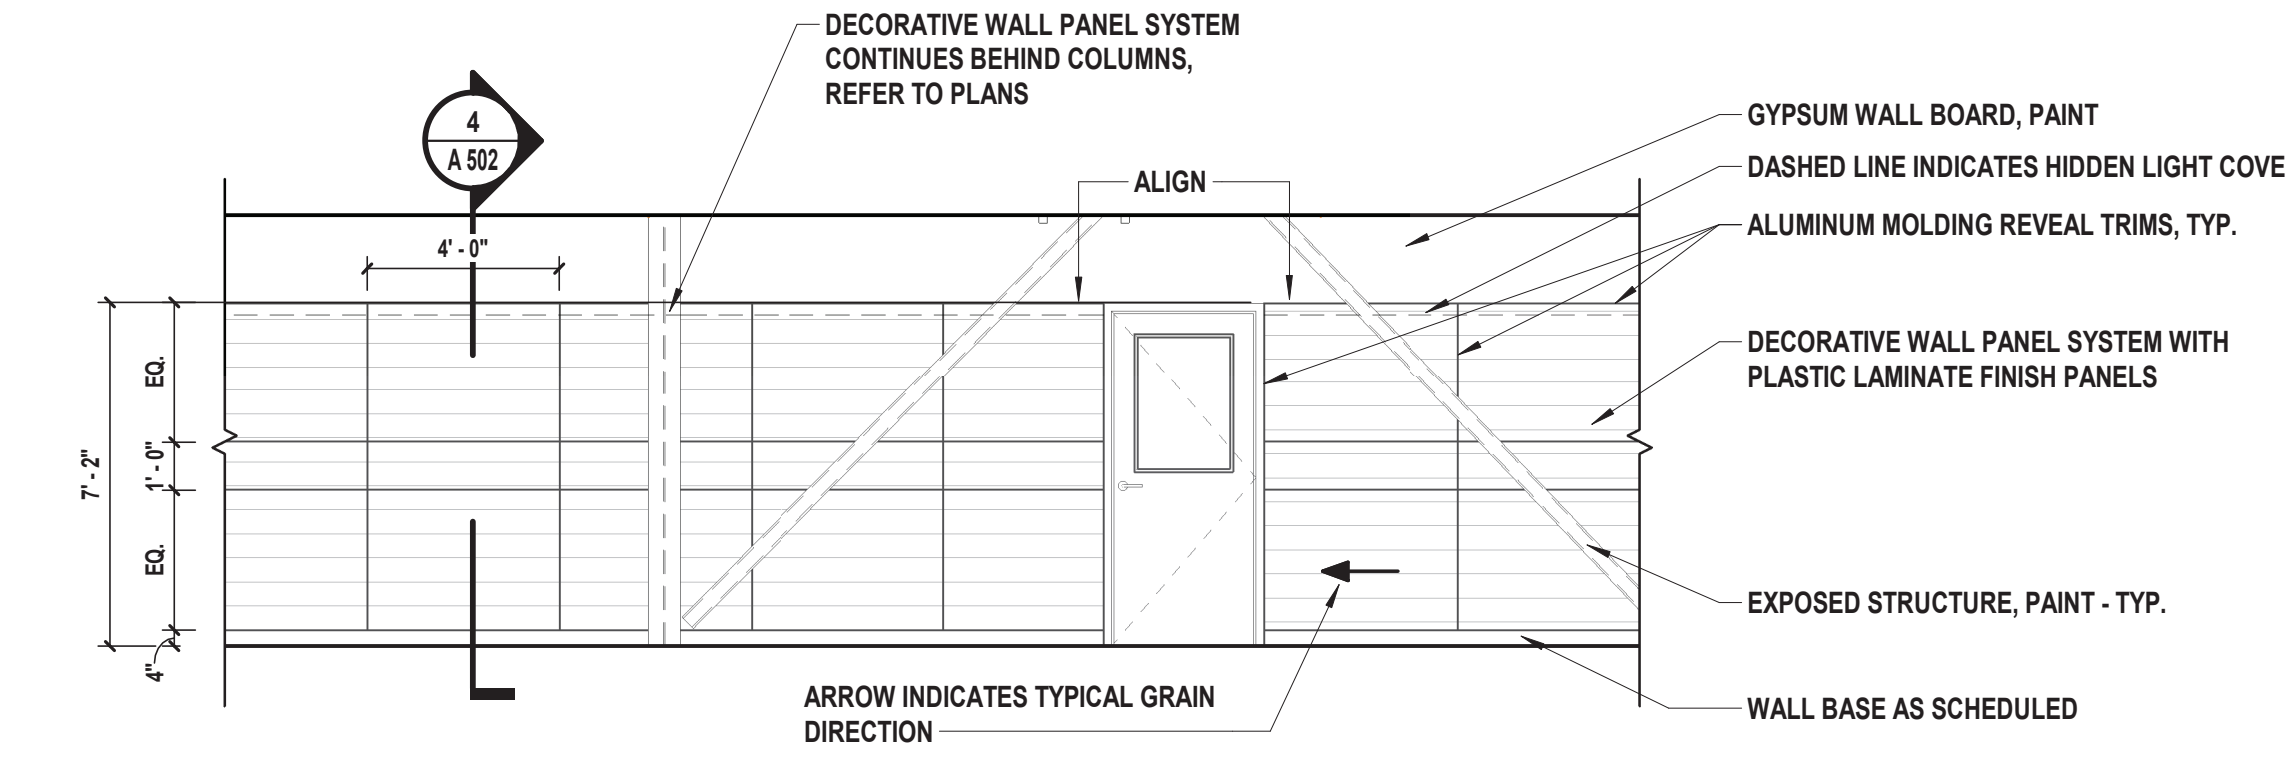


1 Typical Interior Wall Panel Layout
SCALE: 1/4" = 1'-0"

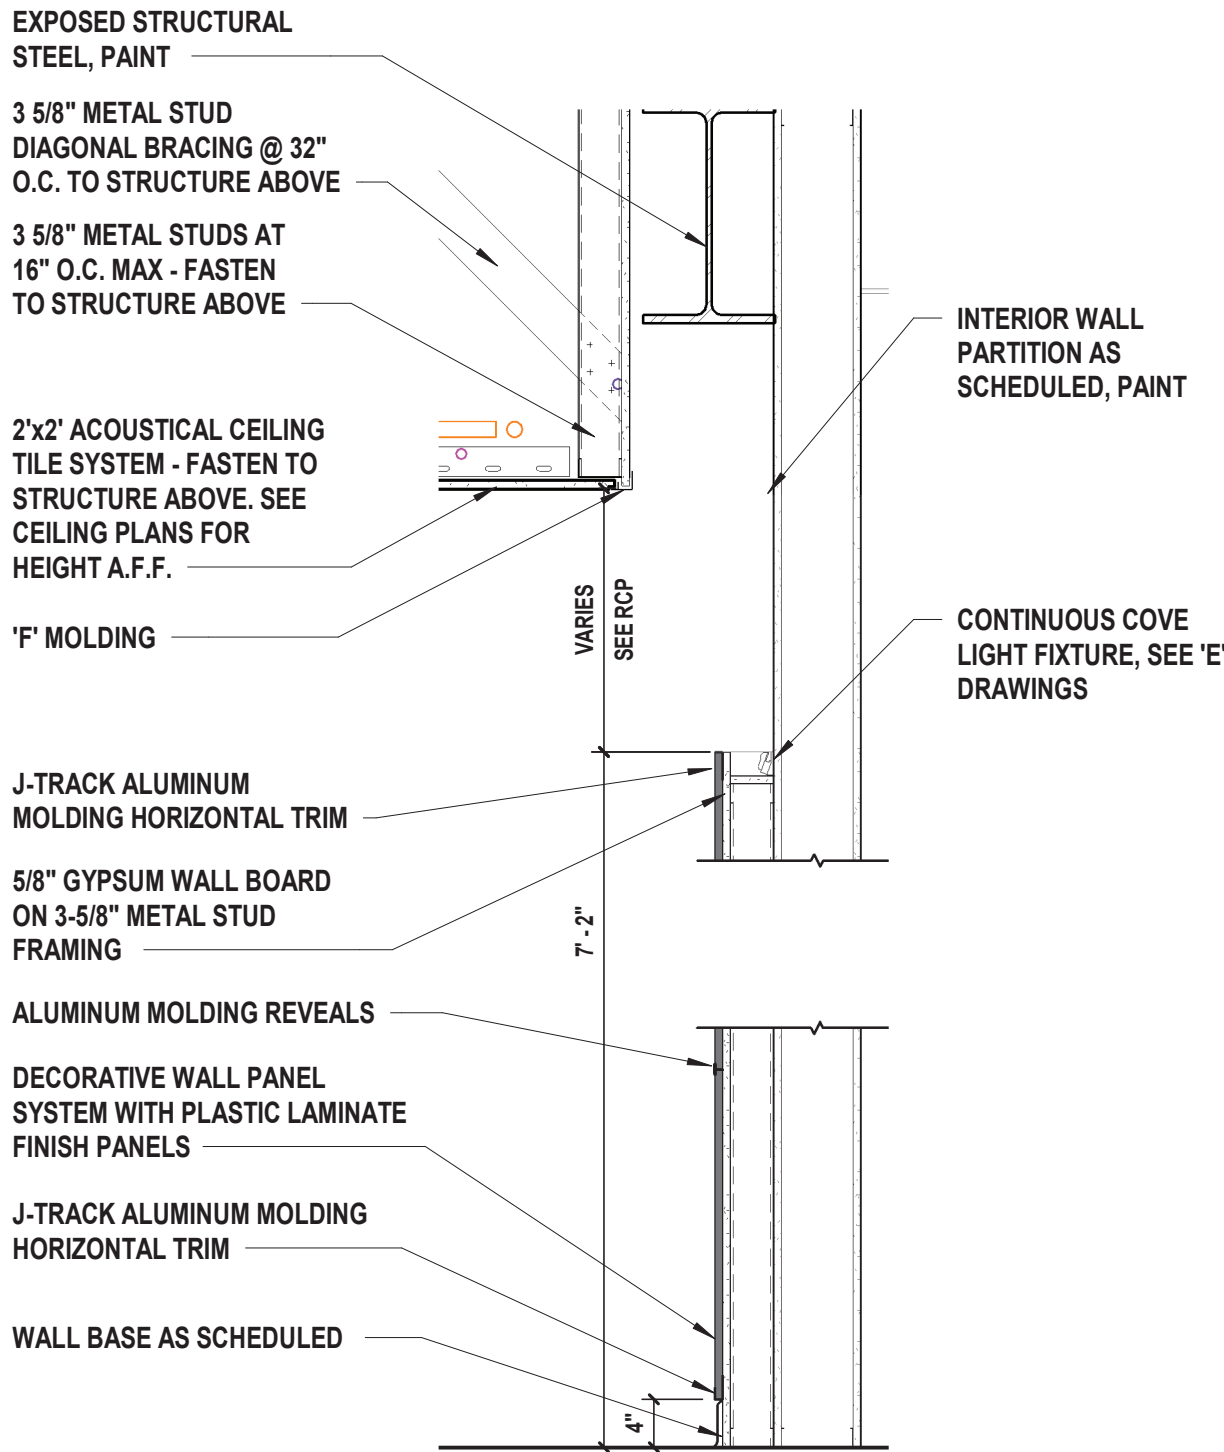


4 Interior Wall Panel and Light Cove Section
SCALE: 3/4" = 1'-0"

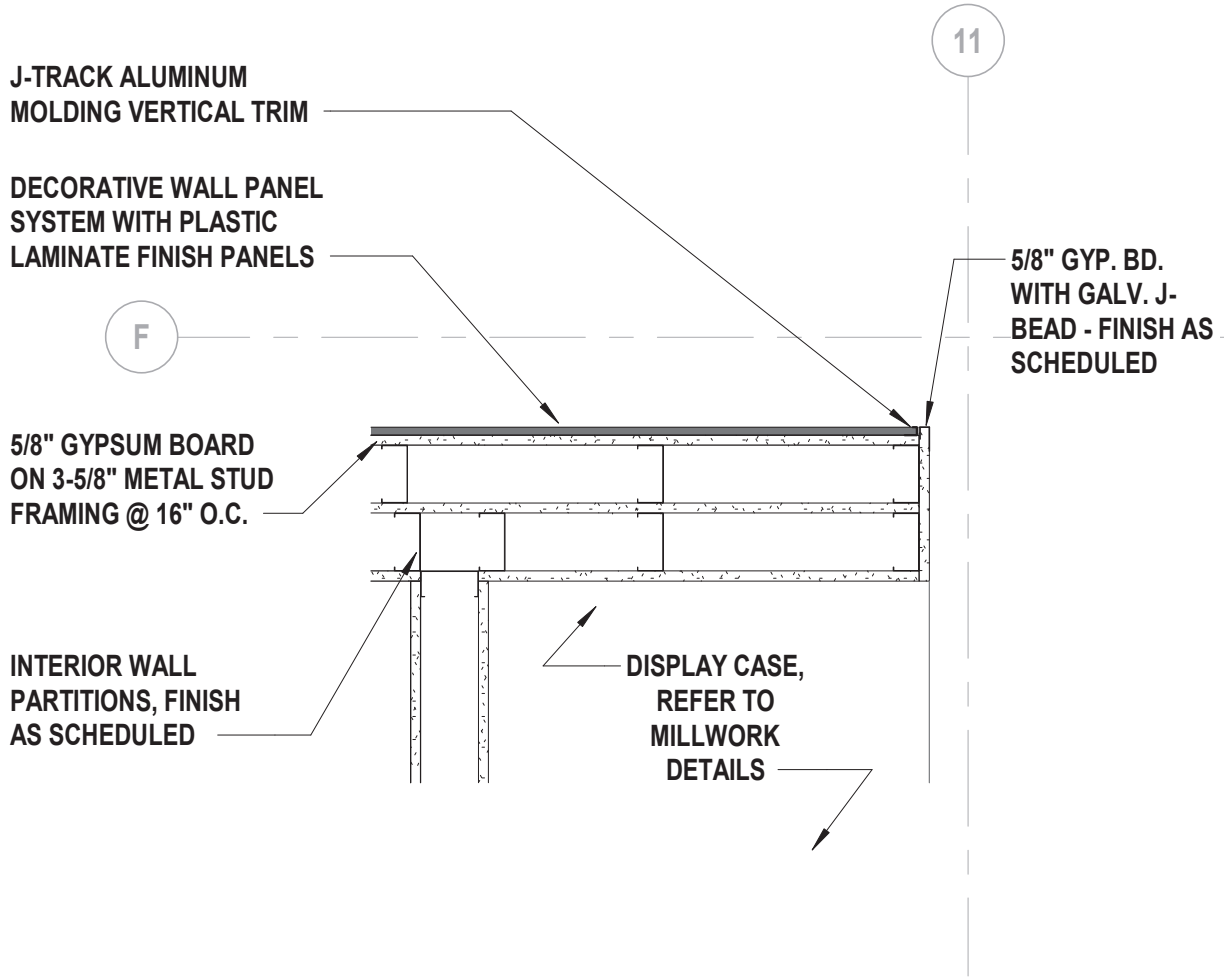








5 Interior Wall Panel Outside Corner
SCALE: 1" = 1'-0"

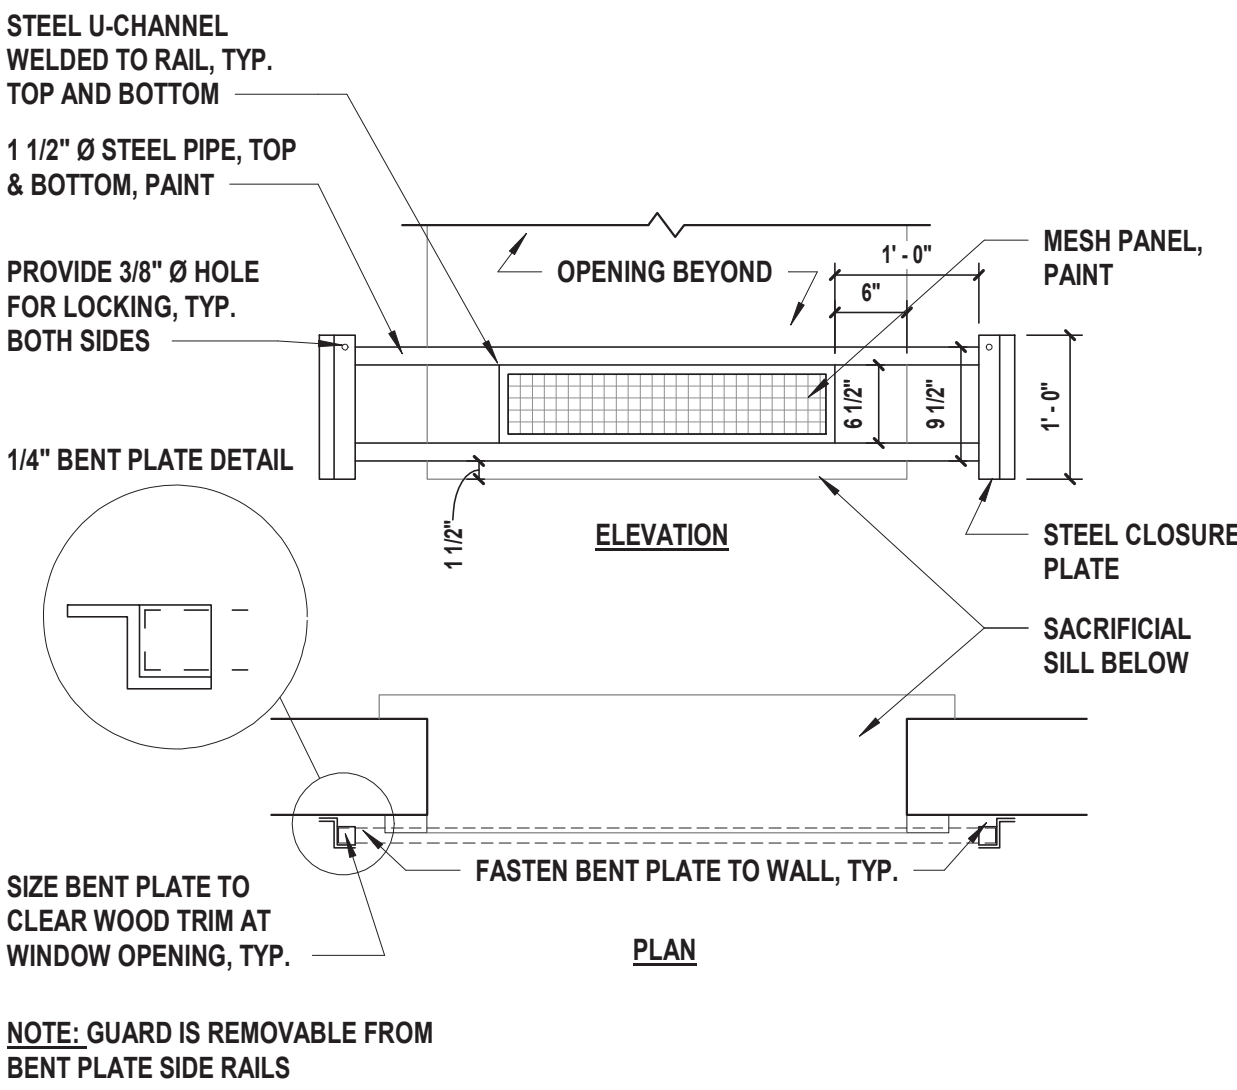

6 Opening Guard Detail
SCALE: 3/4" = 1'-0"

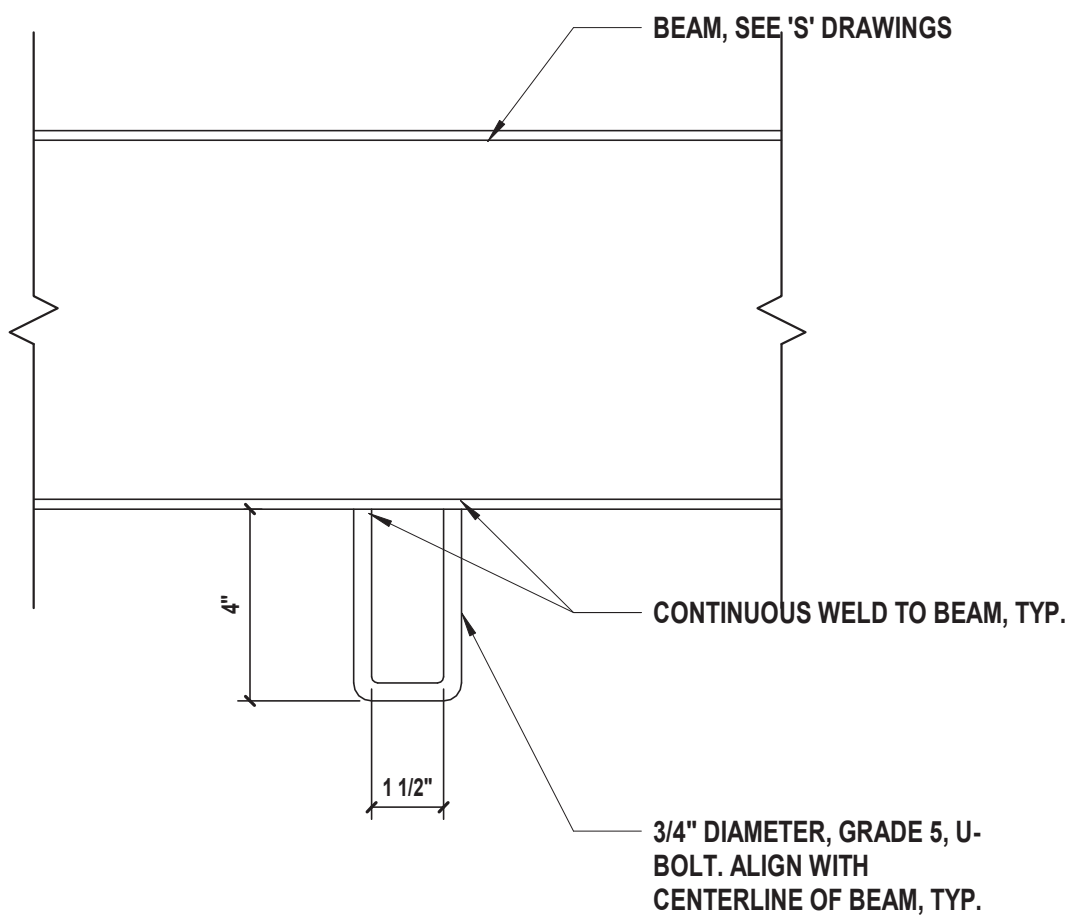

7 Training Window U-Bolt
SCALE: 3" = 1'-0"

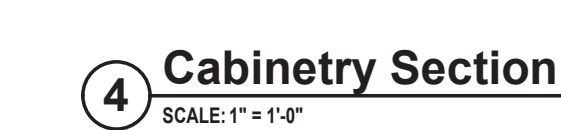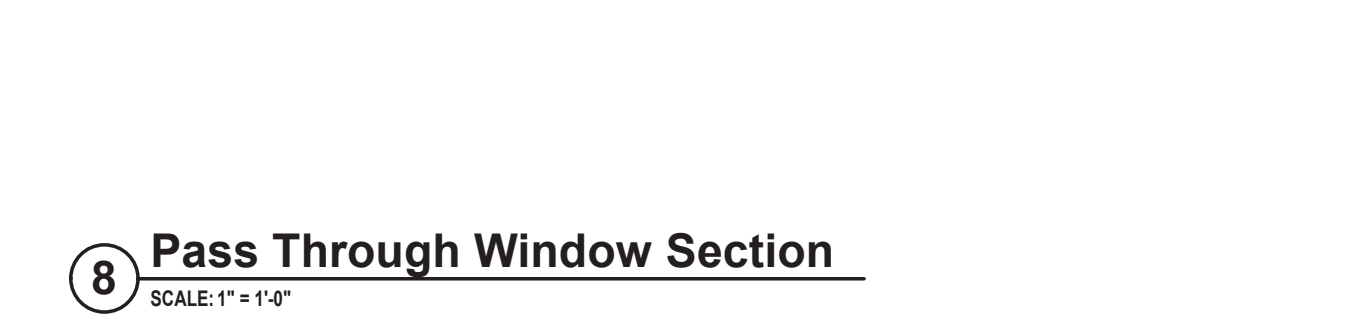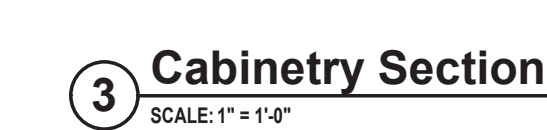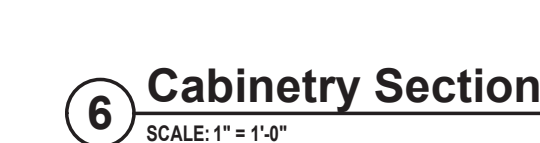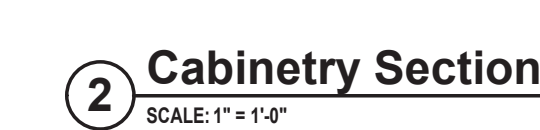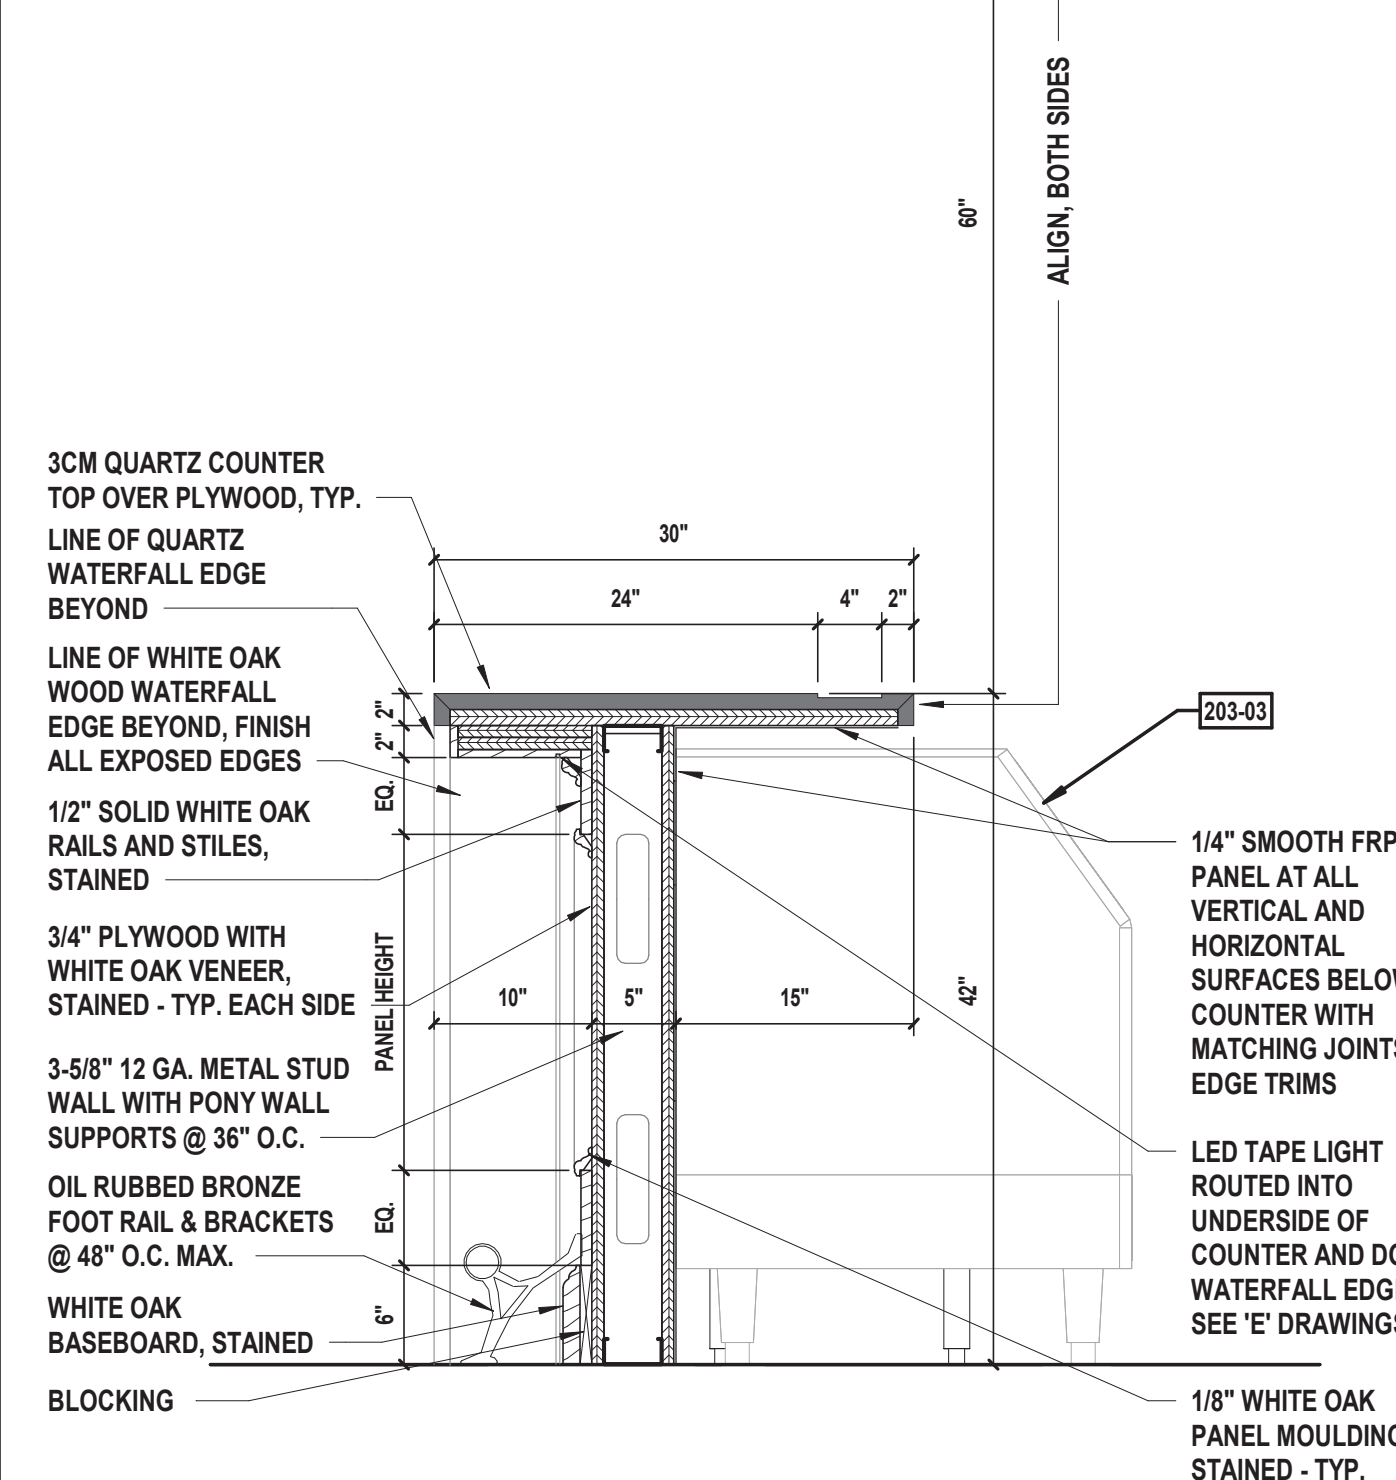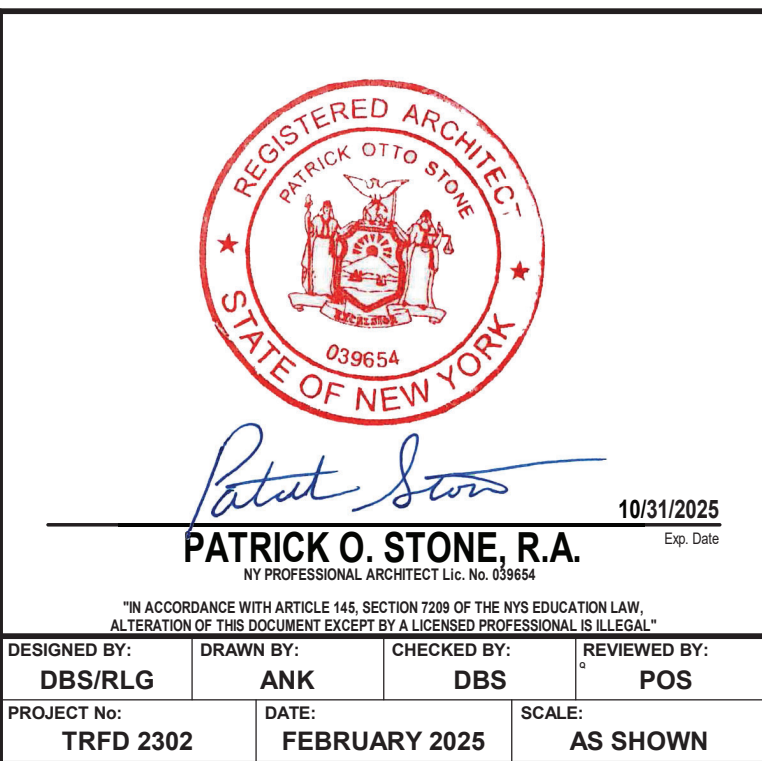[illegible]

**THIELLS
ROSEVILLE FIRE
DISTRICT**

**NEW 26-100 FIRE
HEADQUARTERS**



65 W RAMAPO ROAD
GARNERVILLE, NY 10923

CONTRACT


**CONTRACT G
GENERAL CONSTRUCTION**

STATUS **FINAL BID DOCUMENT**


SHEET TITLE	
-------------	--

MILLWORK DETAILS


DRAWING No. **A 503.00**

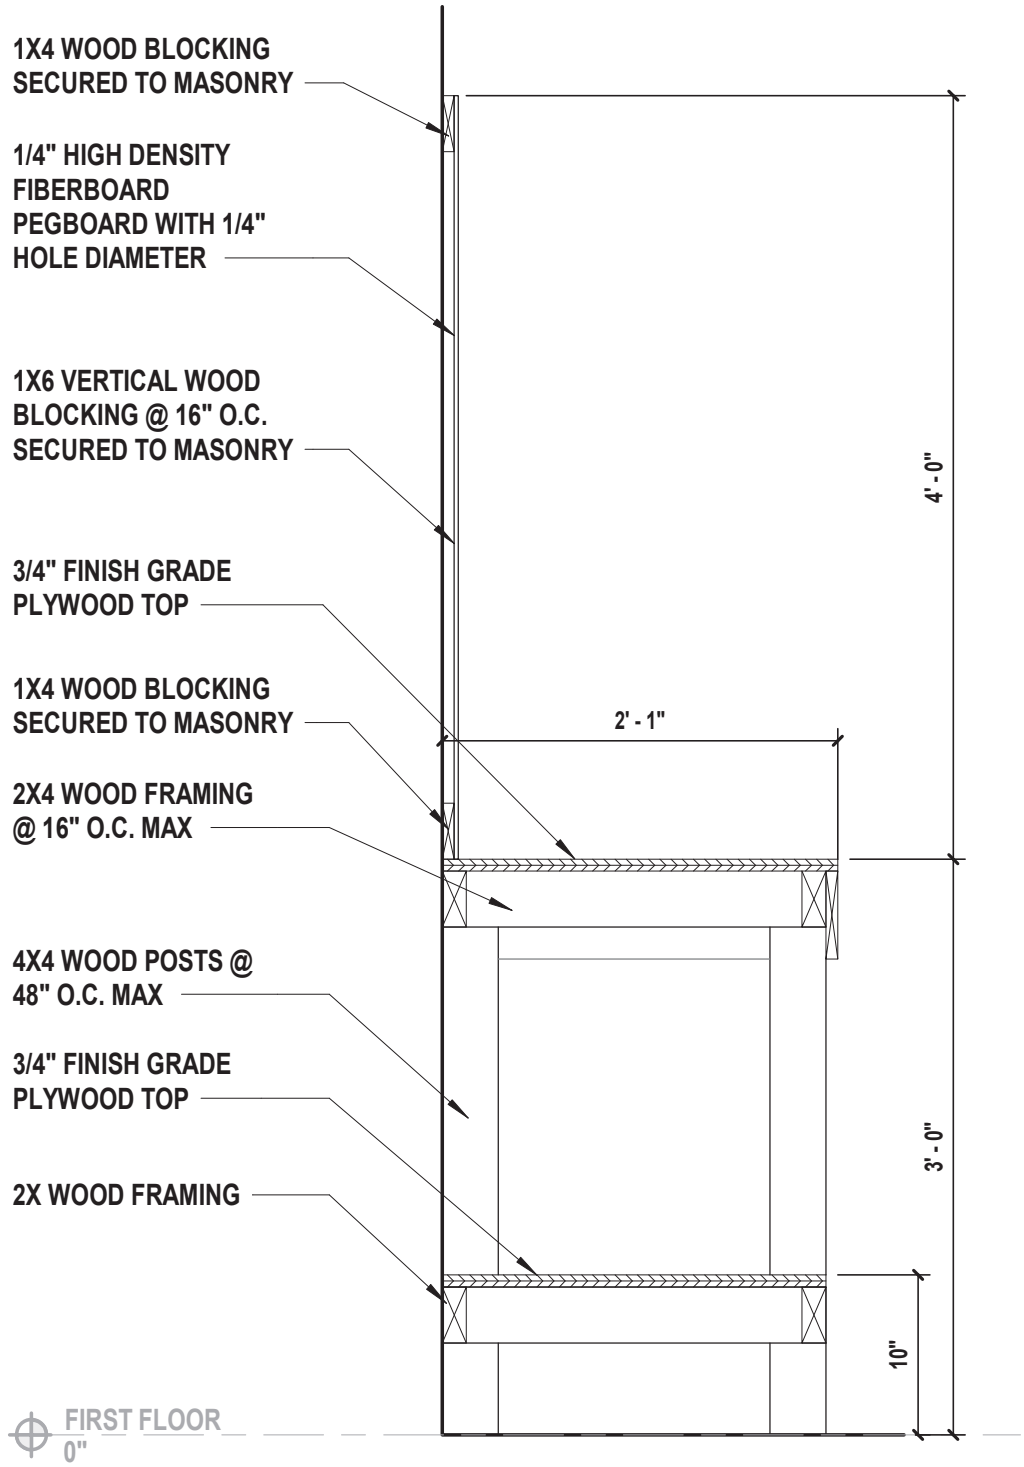

1 Workbench Detail
SCALE: 1" = 1'-0"

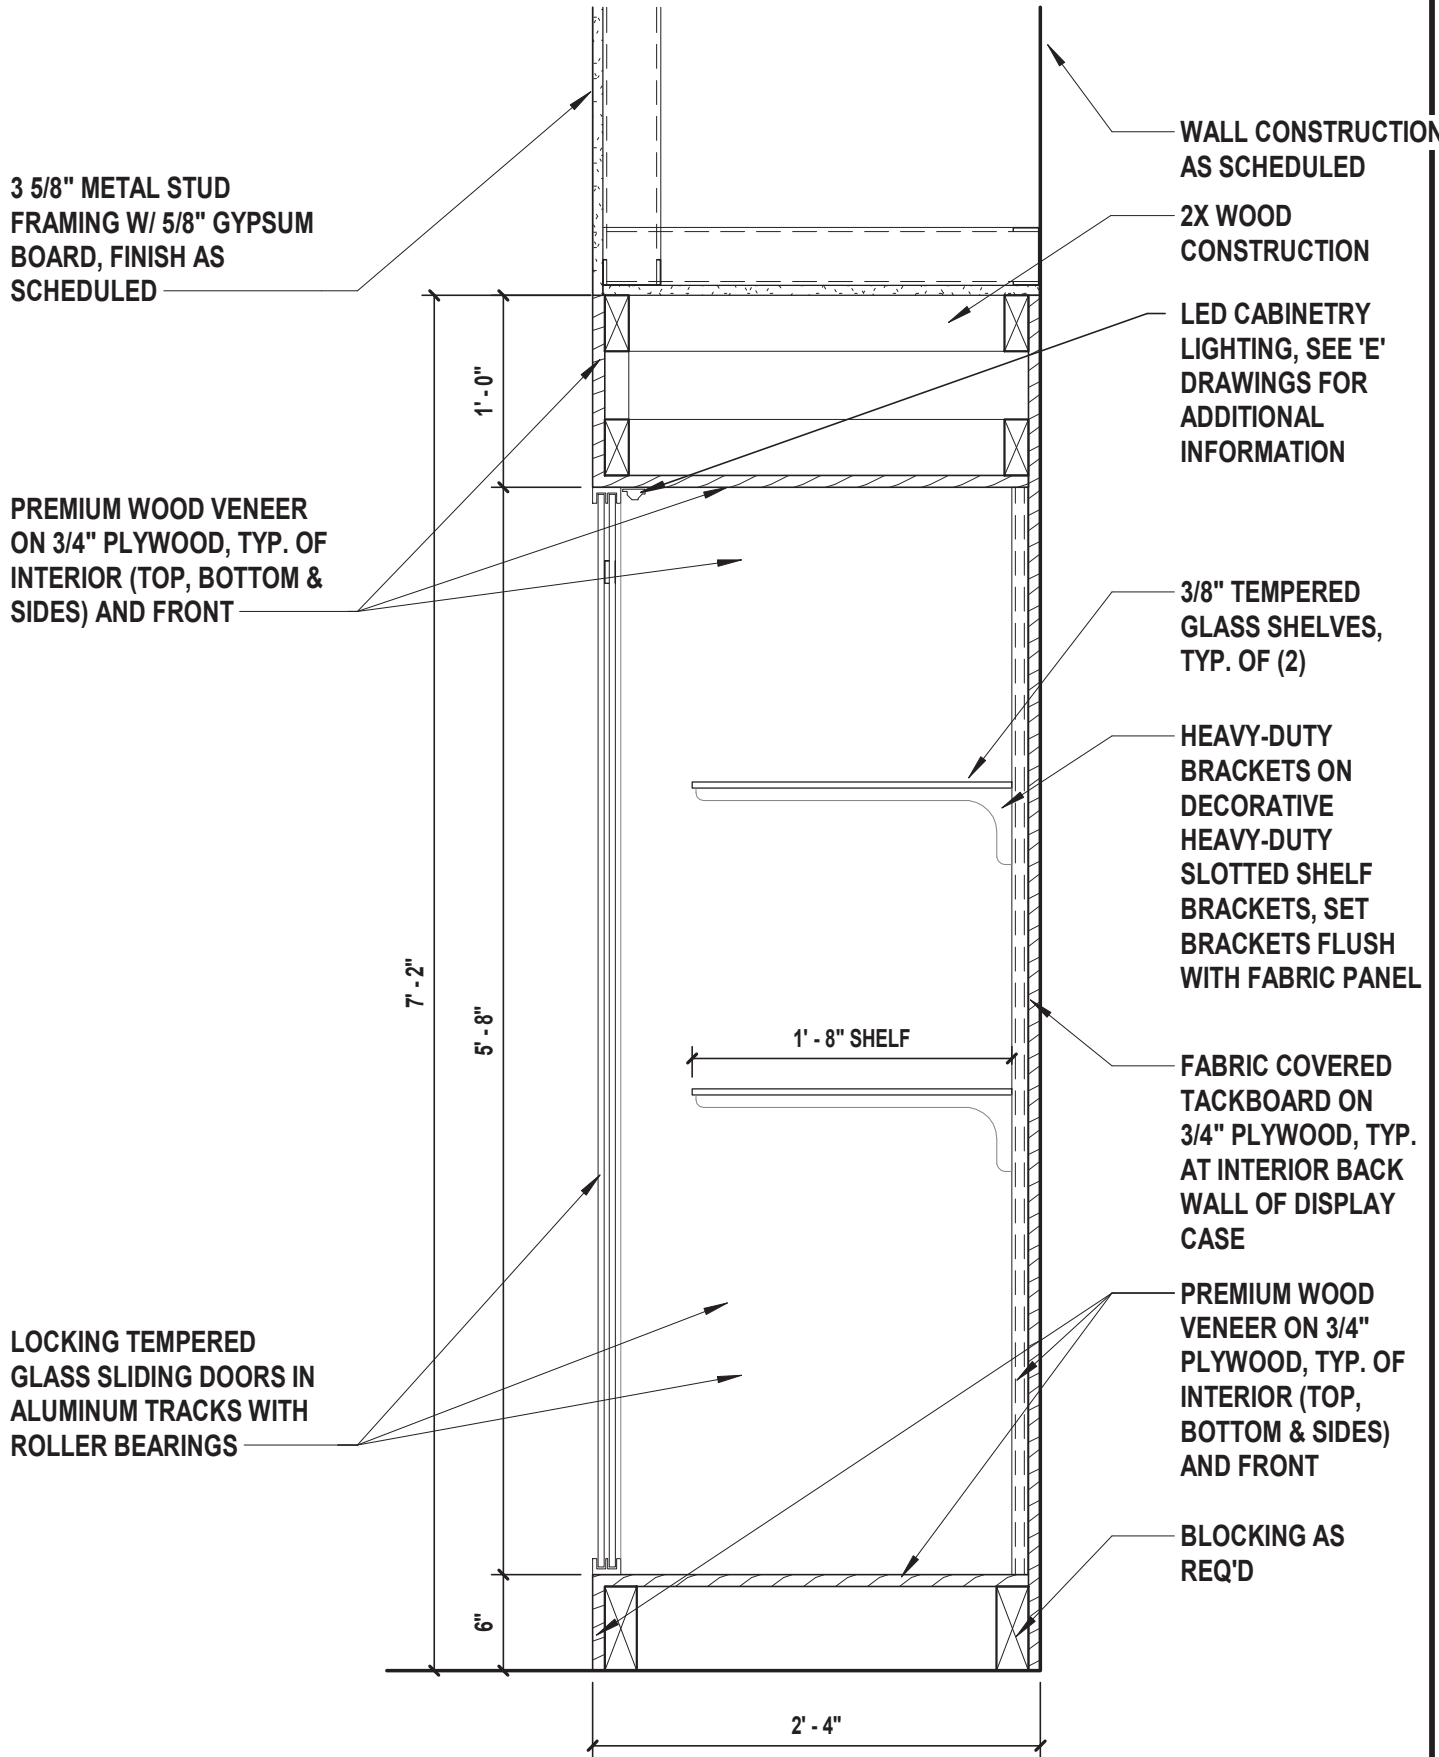

2 Display Case Section Detail
SCALE: 1" = 1'-0"

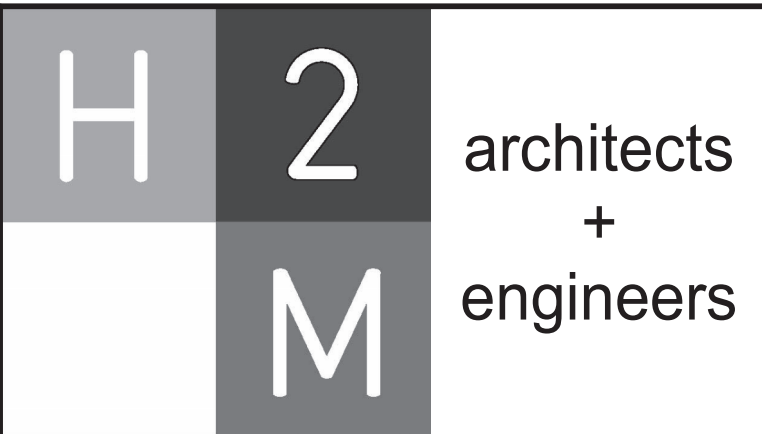

538 Broad Hollow Road, 4th Floor East
Melville, NY 11747
631.756.8000 • www.h2m.com
NY Architecture & Landscape Architecture: No Certificate Required
NY Engineering Certificate of Authorization No.: 0018178

CONSULTANTS:		

MARK	DATE	DESCRIPTION

10/31/2025
Exp. Date

PATRICK O. STONE, R.A.
NY PROFESSIONAL ARCHITECT LIC. No. 039654

DESIGNED BY:
DBS/RLG

DRAWN BY:
ANK/RLG

CHECKED BY:
DBS

REVIEWED BY:
POS

PROJECT No:
TRFD 2302

DATE:
FEBRUARY 2025

SCALE:
AS SHOWN

*IN ACCORDANCE WITH ARTICLE 148, SECTION 1209 OF THE NYS EDUCATION LAW,
ALTACTION OF THIS DOCUMENT EXCEPT BY A LICENSED PROFESSIONAL IS ILLEGAL.*

CLIENT

THIELLS
ROSEVILLE FIRE
DISTRICT

NEW 26-100 FIRE
HEADQUARTERS

65 W RAMAPO ROAD
GARNERVILLE, NY 10923

CONTRACT

CONTRACT G
GENERAL CONSTRUCTION

STATUS

FINAL BID DOCUMENT

SHEET TITLE

MILLWORK DETAILS

DRAWING No.

A 504.00

		10/31/2025	
		Exp. Date	
PATRICK O. STONE, R.A.			
NY REGISTERED ARCHITECT Lic. No. 029654			
"IN ACCORDANCE WITH ARTICLE 146, SECTION 1 OF THE VES EDUCATION LAW: "ALTERATION OF THIS DOCUMENT EXCEPT BY A LICENSED PROFESSIONAL IS ILLEGAL."			
DESIGNED BY:	DRAWN BY:	CHECKED BY:	REVIEWED BY:
DBS/RLG	AK/RLG	DBS	POS
PROJECT No:	DATE:	SCALE:	
TRFD 2302	FEBRUARY 2025		AS SHOWN

**THIELLS
ROSEVILLE FIRE
DISTRICT**

CONTRACT

CONTRACT G
GENERAL CONSTRUCTION


STATUS	FINAL BID DOCUMENT
--------	--------------------

SHEET TITLE



FINISH SCHEDULE

DRAWING No. **A 600.00**

FINISH NOTES			
1.	ALL INTERIOR FINISHES ARE TO MEET OR EXCEED THE REQUIREMENTS OF NYSCRR PARTS 771 & 772.	8.	CONTRACTOR IS RESPONSIBLE TO INCLUDE IN BASE BID PRICING ALL SEALANTS, ADHESIVES AND MATERIALS REQUIRED TO PROPERLY COMPLETE THE INSTALLATION OF ALL FINISHES AS INDICATED.
2.	SEE SPECIFICATIONS FOR INTERIOR FINISH MINIMUM REQUIREMENTS.	9.	ALL EXPOSED OUTSIDE CORNERS OF FWB ARE TO RECEIVE CORNER GUARDS UNLESS NOTED OR DIRECTED OTHERWISE BY THE ARCHITECT.
3.	SEE REFLECTED CEILING PLAN FOR CEILING HEIGHTS, SOFFITS, AND SAC TYPES. REFER TO SPECIFICATIONS 995113 FOR ACOUSTICAL CEILING TYPES AND ADDITIONAL INFORMATION.	10.	ALL EXPOSED FIRE SPRINKLER, DUCTWORK, CONDUIT, PIPING, ETC. SHALL BE PAINTED, COLOR TO BE DETERMINED BY ARCHITECT UNLESS NOTED OTHERWISE.
4.	THIS SCHEDULE SERVES AS A GENERAL LIST OF FINISH ITEMS AND IS NOT A LIST OF ALL FINISH ITEMS WITHIN A ROOM OR SPACE. REFER TO ALL CONTRACT DOCUMENTS, DRAWINGS, AND SPECIFICATIONS TO DETERMINE ALL REQUIRED FINISHES AND FINISH ITEMS.	11.	CONTRACTOR SHALL PROVIDE SHOP DRAWINGS FOR ARCHITECT'S REVIEW AND APPROVAL PRIOR TO INSTALLATION OF FINISH FLOOR MATERIALS.
5.	CONTRACTOR SHALL FIELD VERIFY ALL DIMENSIONS FOR QUANTITY TAKEOFFS AND FABRICATION OF MATERIALS.	12.	IN ALL ROOMS WITH TILE FLOORS AND FLOOR DRAINS, FINISH SHALL BE LOCALLY SLOPED TO DRAIN. NO RECESS IN SLAB.
6.	CONTRACTOR IS REQUIRED TO FURNISH AND INSTALL ALL FINISHES AS INDICATED IN ACCORDANCE WITH MANUFACTURERS INSTRUCTIONS AND RECOMMENDATIONS.	13.	ELEVATOR CAB SHALL RECEIVE LVT FLOORING CONSISTENT WITH CORRIDOR FINISHES
7.	ALL ROOMS SCHEDULED TO BE PAINTED SHALL BE PREPARED, PRIMED, AND PAINTED OR STAINED AS NOTED INCLUDING ALL WALL SURFACES, EXPOSED CEILINGS, MOULDING, DOOR FRAMES, DOOR TRIM, WINDOW TRIM, CLOSETS, ETC.		

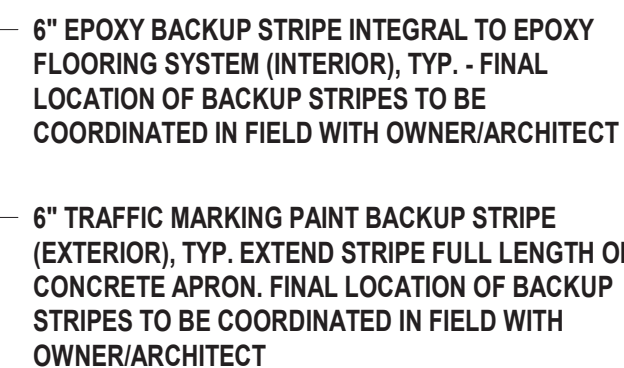

Building Mounted Signage

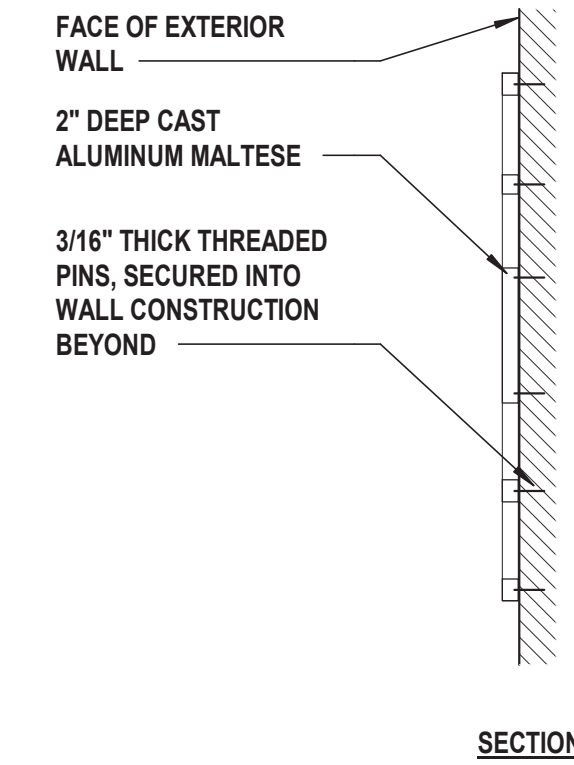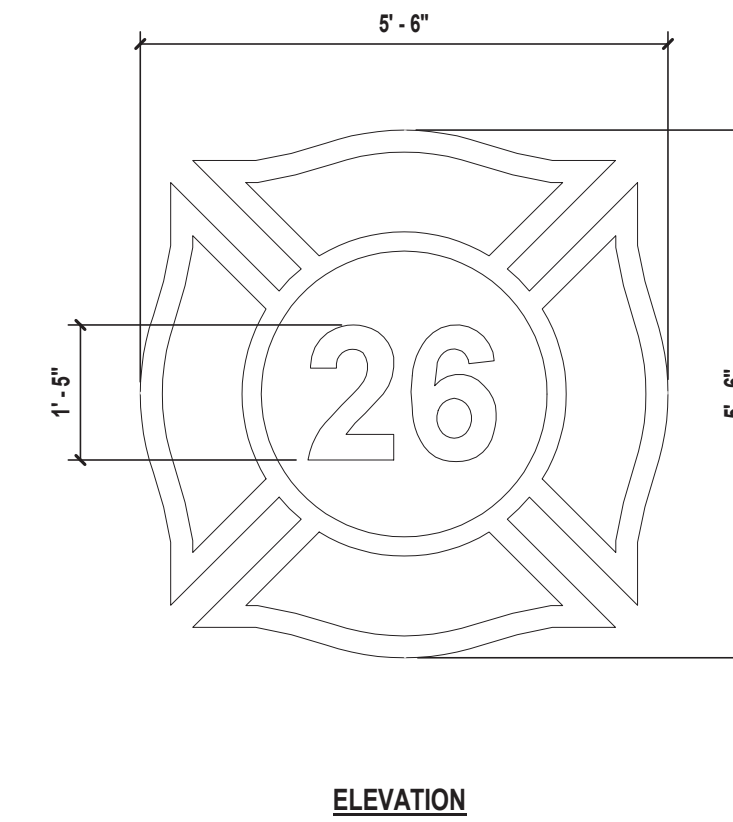

3/16" CLEAR LEXAN BACK

2"

FACE OF EXTERIOR WALL

3/16" THICK 3" LONG
THREADED PINS, TYP.
EMBEDDED INTO MASONRY
WALL CONSTRUCTION


WHITE LED
MODULES

1" STANDOFF
BRACKETS

120 PRIMARY ELECTRIC INTO
WALL (1 PER CHARACTER) -
SEE 'E' DRAWINGS


SECTION

3 Cast Aluminum Maltese

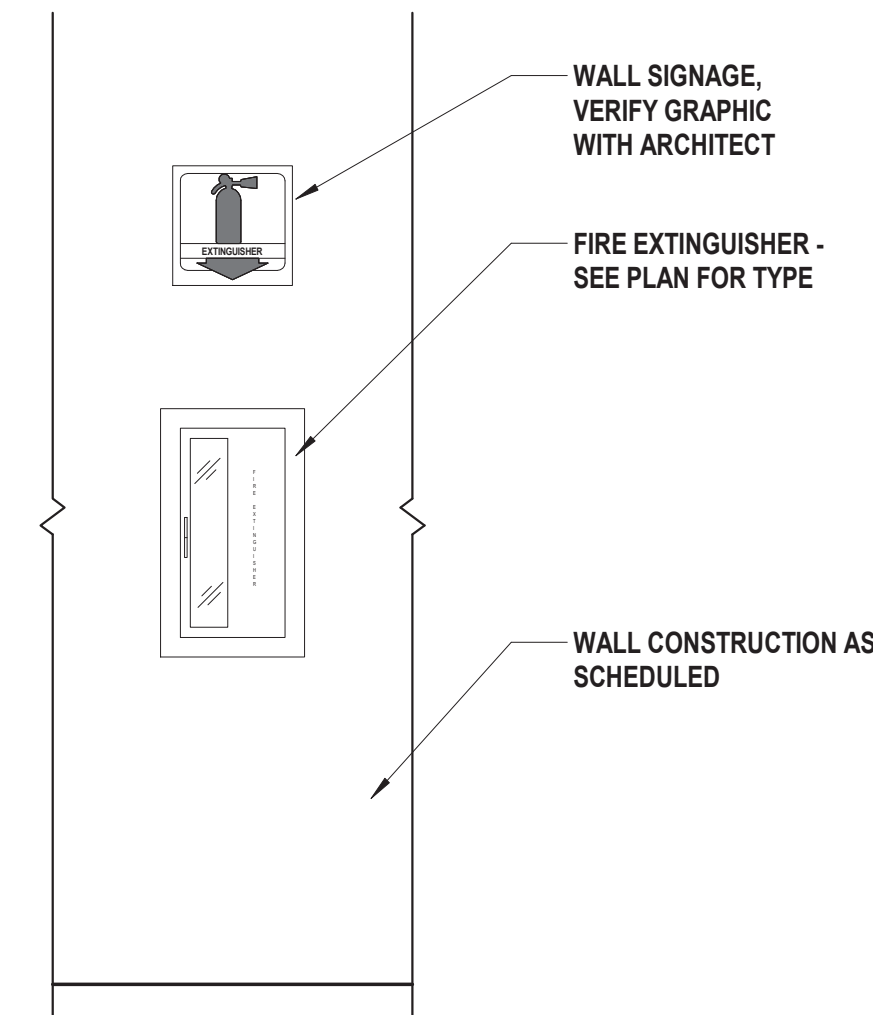

-

- ## 5 Fire Extinguisher Signage

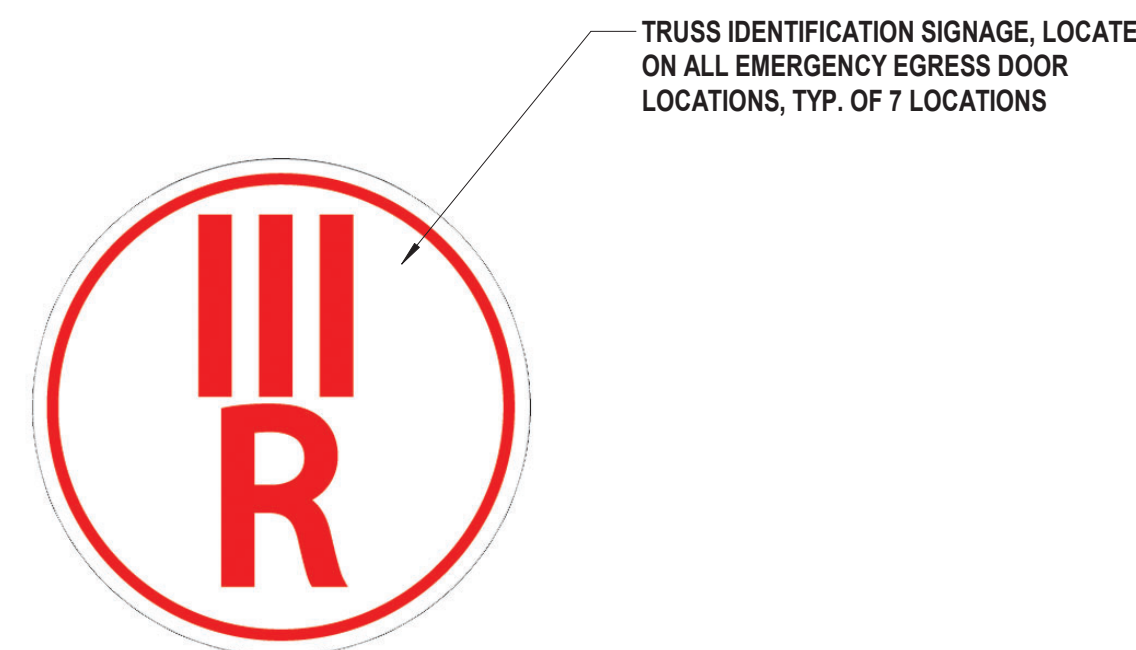

- 7 Truss Identification Signage**
SCALE: 3" = 1'-0"

6 Dedication Plaque

1. DETAILS ON THIS SHEET SHALL BE COORDINATED WITH REQUIREMENTS OUTLINED IN SPECIFICATION 101400 OF THE PROJECT MANUAL.
2. REFER TO PROJECT MANUAL FOR LOCATIONS OF ALL SIGNAGE, TYPICAL.
3. MOUNTING LOCATIONS AND PLACEMENTS OF ALL SIGNS SHALL BE CONFIRMED WITH OWNER AND ARCHITECT PRIOR TO INSTALLATION.
4. FOR ALL EXTERIOR SIGNAGE LOCATED ON EXTERIOR OF BUILDING, SEE EXTERIOR ELEVATIONS FOR ADDITIONAL INFORMATION.
5. FINAL DESIGNS, ORIENTATION AND SPACING TO BE DETERMINED IN FIELD WITH OWNER AND ARCHITECT PRIOR TO INSTALLATION.
6. PROVIDE 3/4" CDX PLYWOOD BLOCKING AT ALL AREAS TO RECEIVE SIGNAGE.

- #### 4 Interior Signage



7 Truss Identification Signage
SCALE: 3" = 1'-0"



CONSULTANTS:		

MARK	DATE	DESCRIPTION

REGISTERED ARCHITECT
PATRICK O. STONE
STATE OF NEW YORK
029654


PATRICK O. STONE, R.A.
NY PROFESSIONAL ARCHITECT LIC. NO. 029654

10/31/2025
Exp. Date


"IN ACCORDANCE WITH ARTICLE 145, SECTION 1209 OF THE NYS EDUCATION LAW,
ALTAIRATION OF THIS DOCUMENT EXCEPT BY A LICENSED PROFESSIONAL IS ILLEGAL."

DESIGNED BY: DBS/RLG
PROJECT No: TRFD 2302


DRAWN BY: KAP
DATE: FEBRUARY 2025

CHECKED BY: DBS
SCALE: AS SHOWN


REVIEWED BY: POS

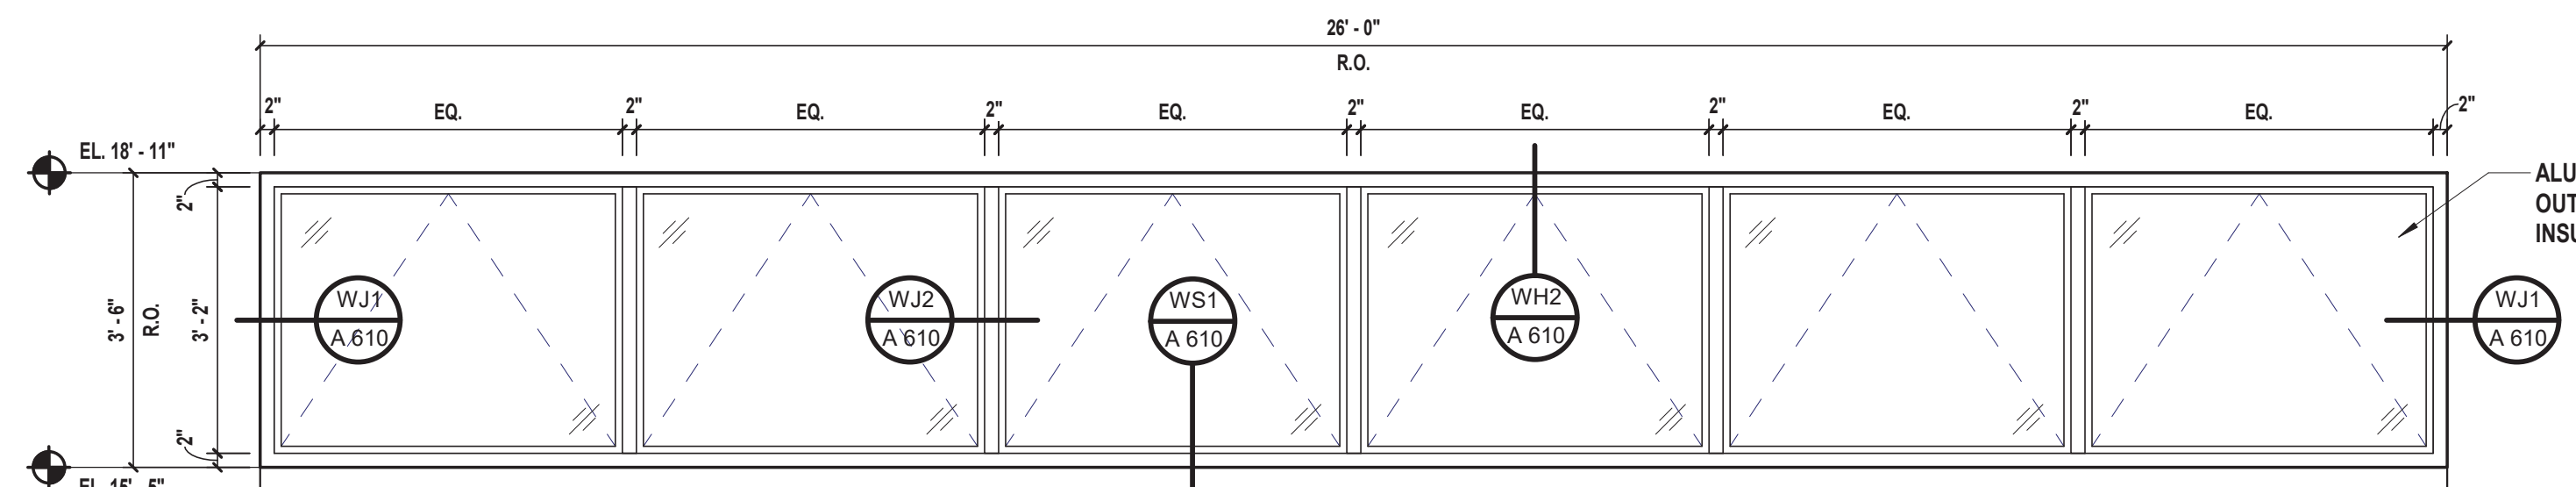


A Window Type A
SCALE: 1/2" = 1'-0"

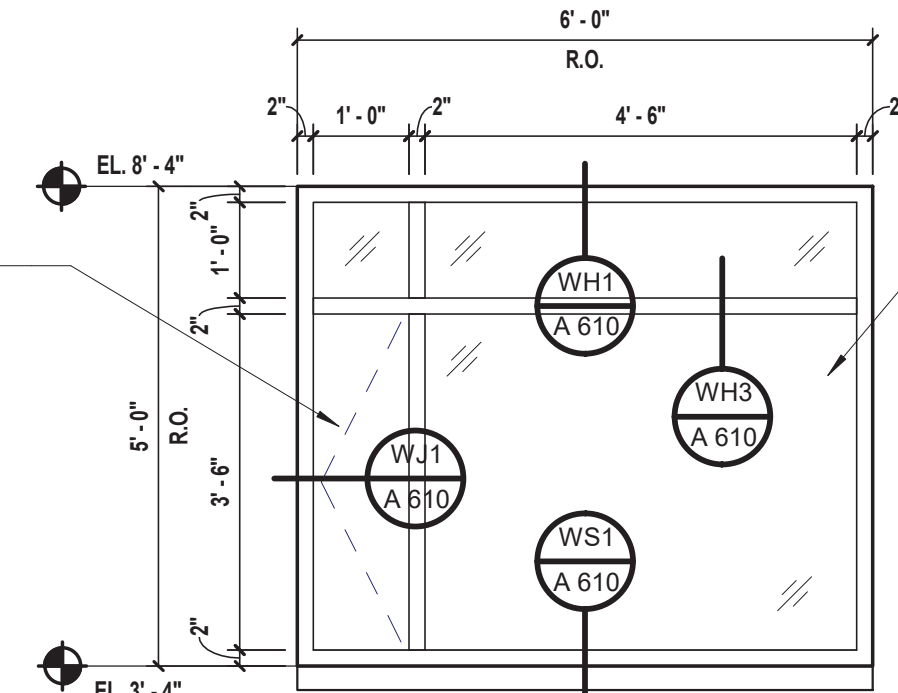


B Window Type B
SCALE: 1/2" = 1'-0"

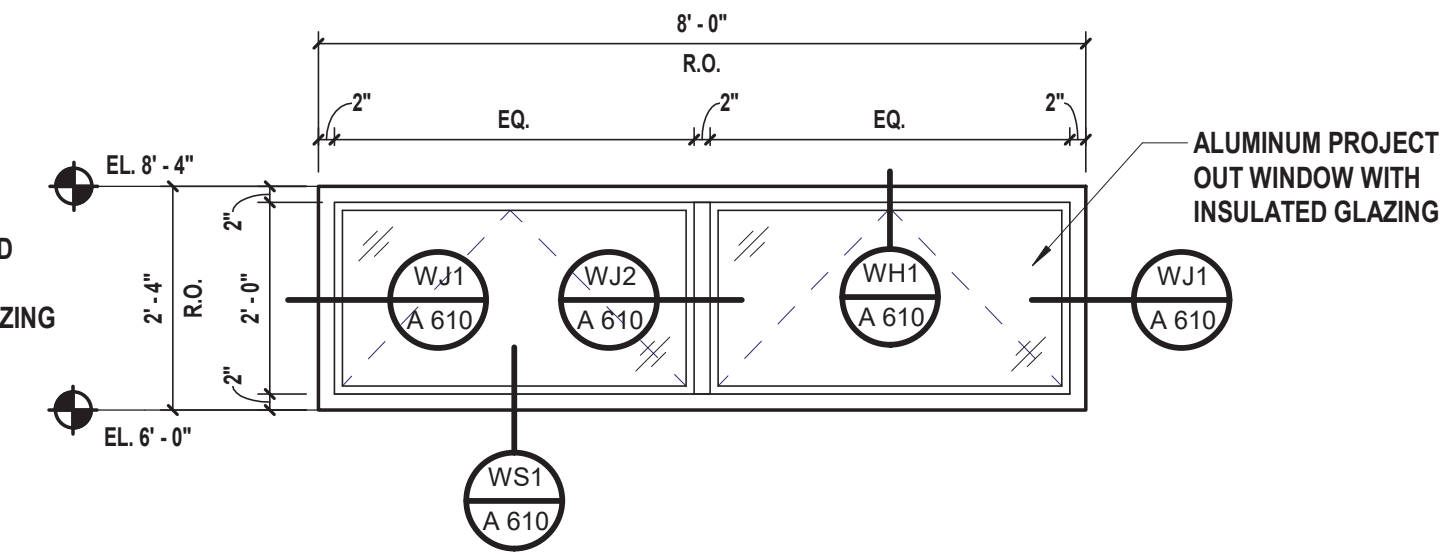


C Window Type C
SCALE: 1/2" = 1'-0"

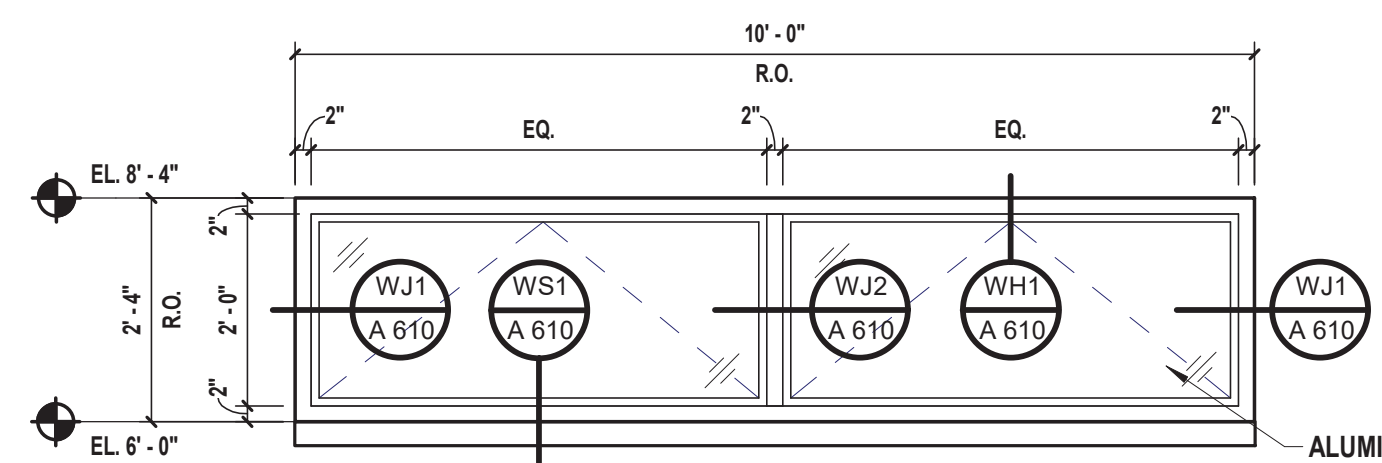


D Window Type D
SCALE: 1/2" = 1'-0"

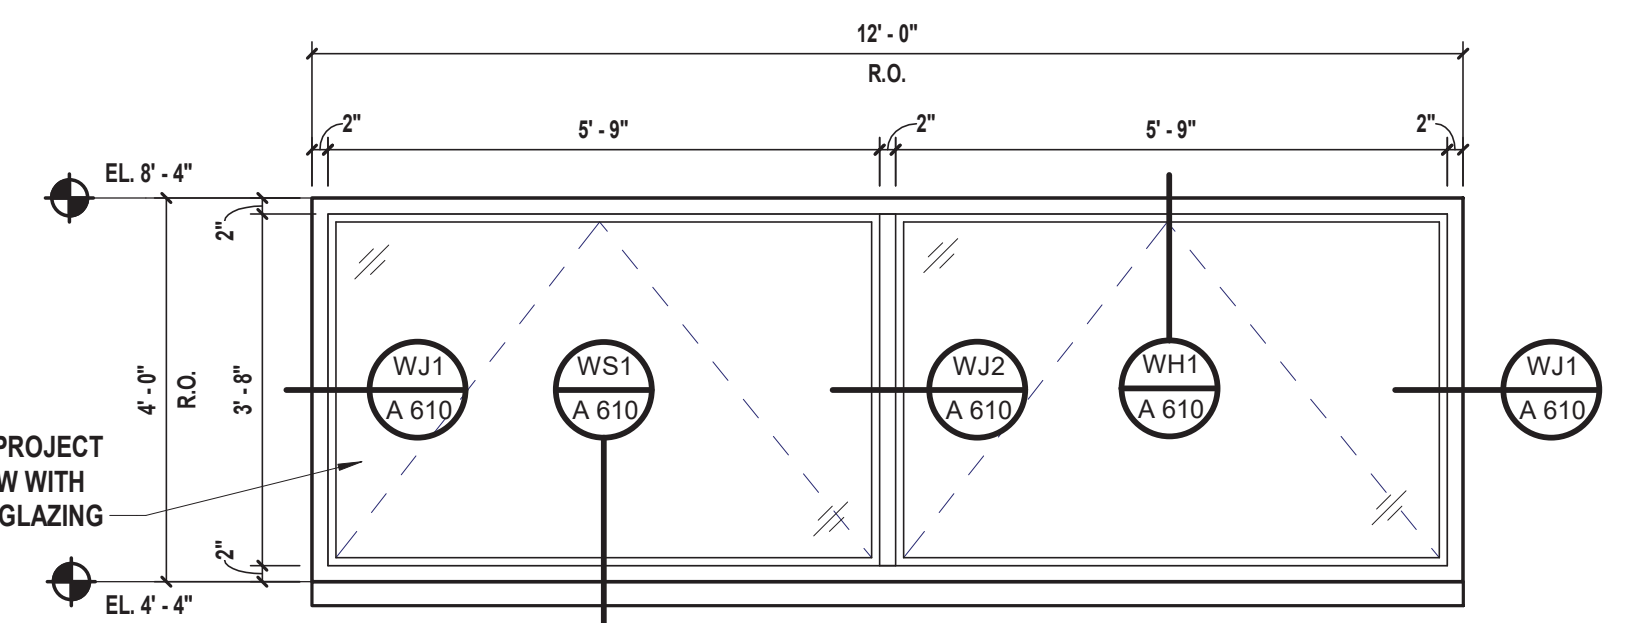


E Window Type E
SCALE: 1/2" = 1'-0"

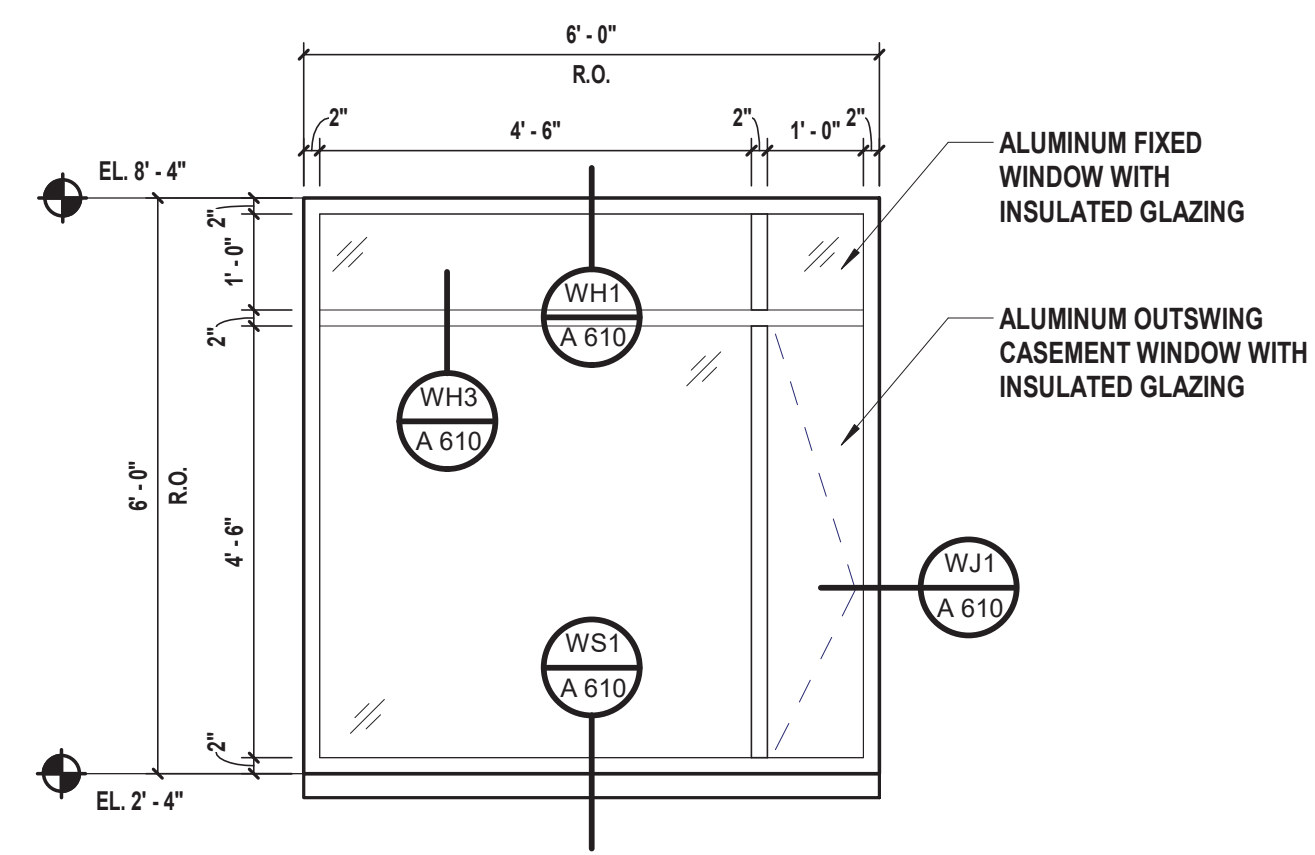


F Window Type F
SCALE: 1/2" = 1'-0"

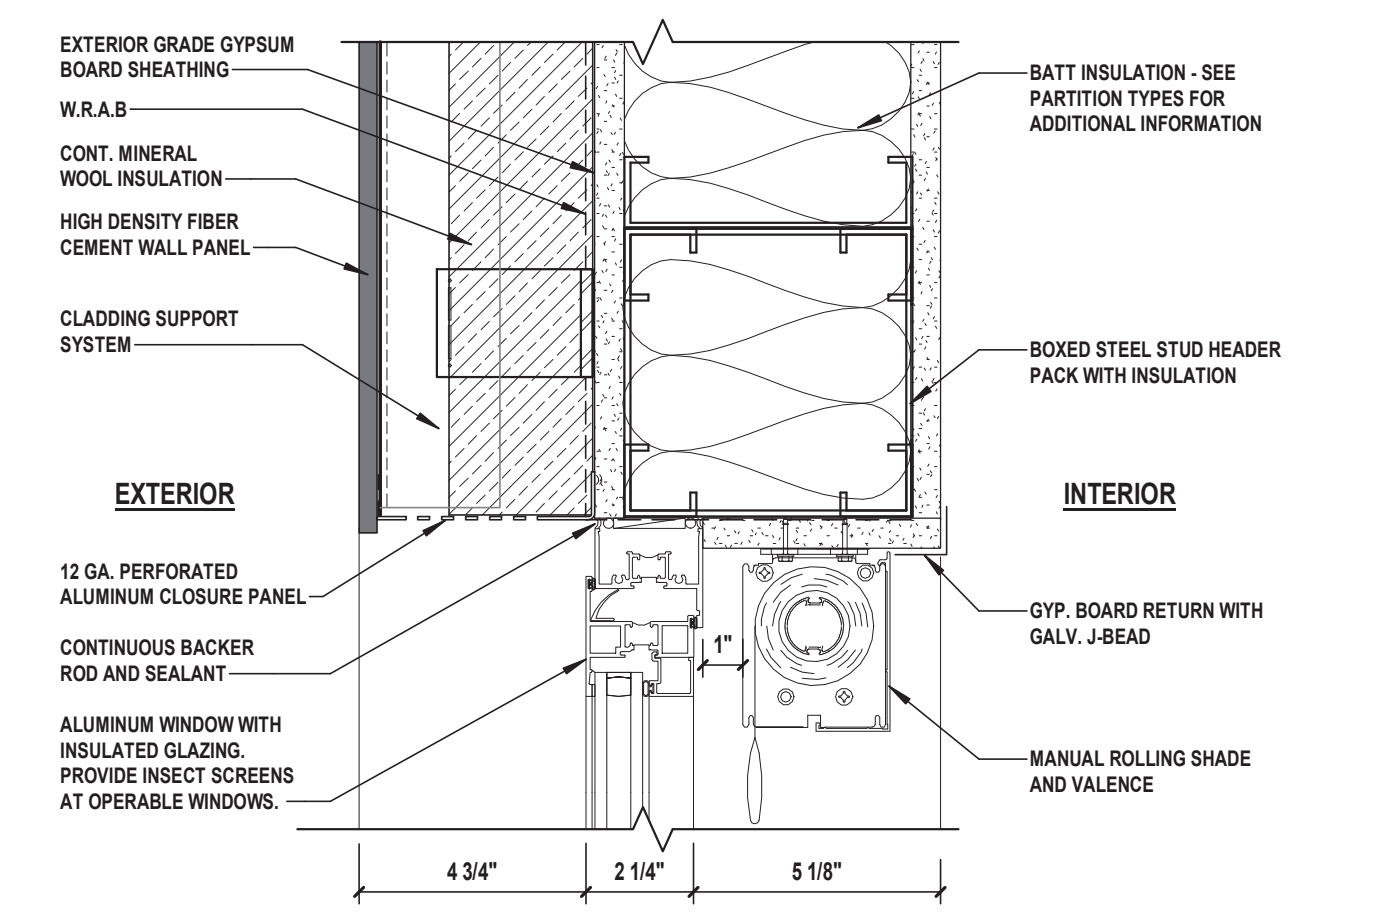


WH1 Window Head Detail
SCALE: 3" = 1'-0"

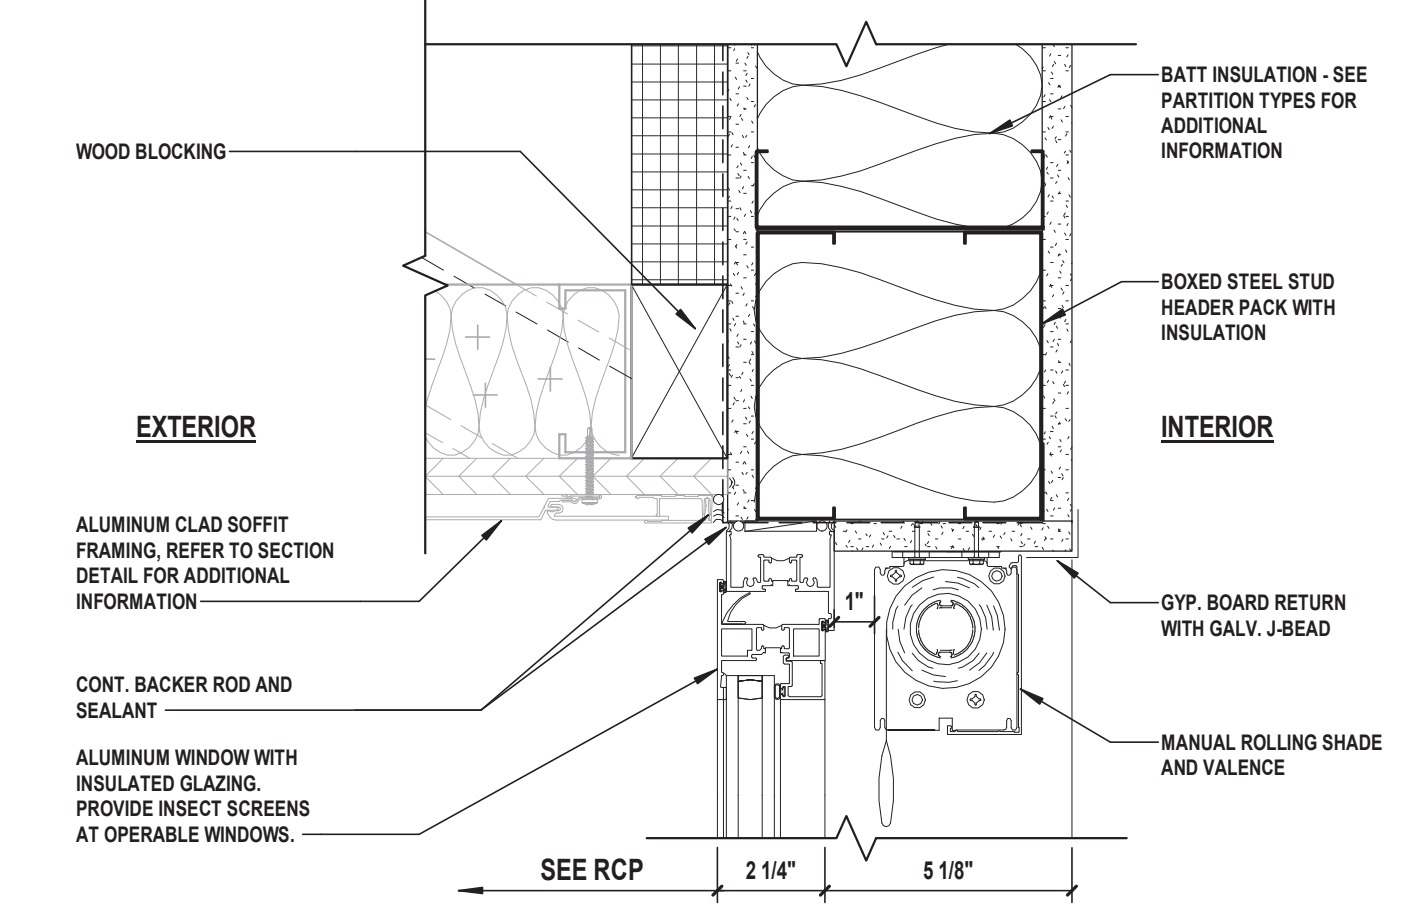


WH2 Window Head Detail
SCALE: 3" = 1'-0"

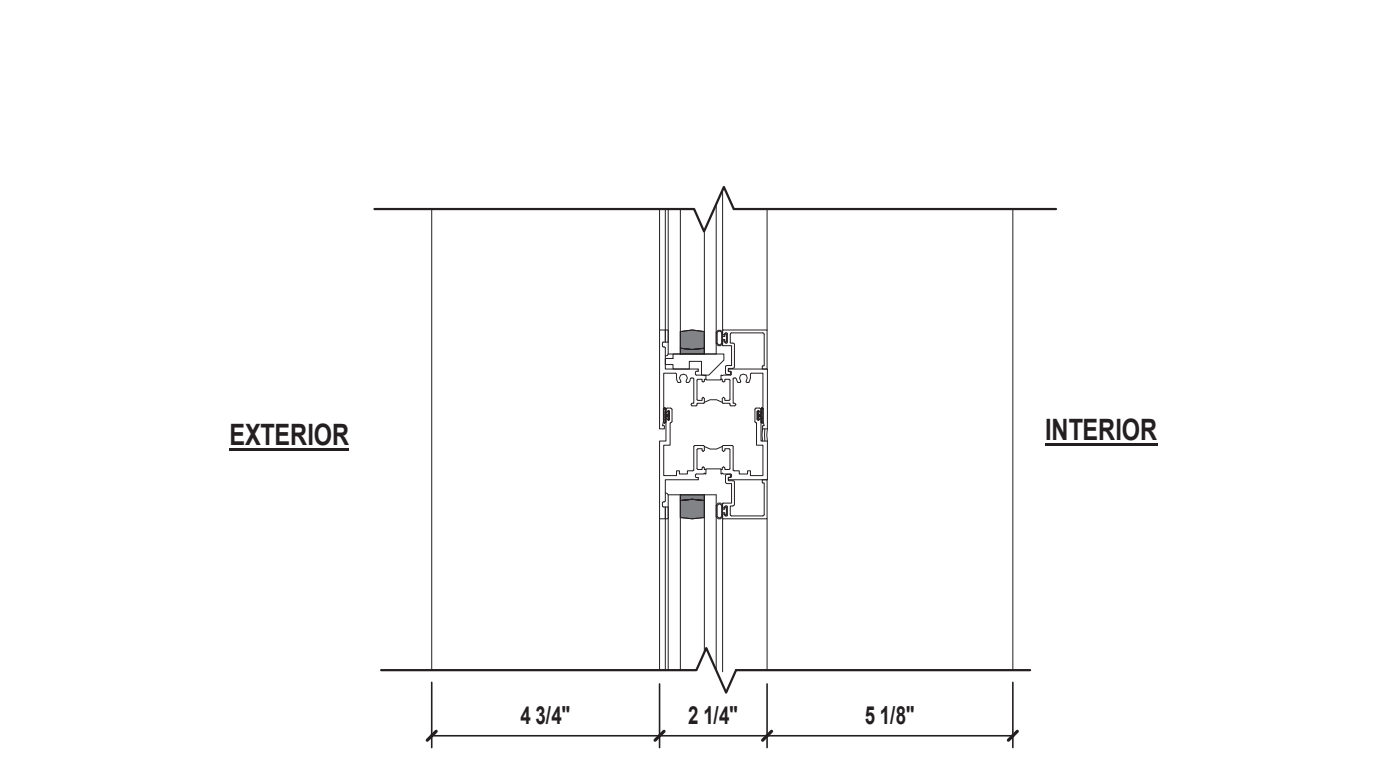


WH3 Fixed Stack Horizontal Detail
SCALE: 3" = 1'-0"

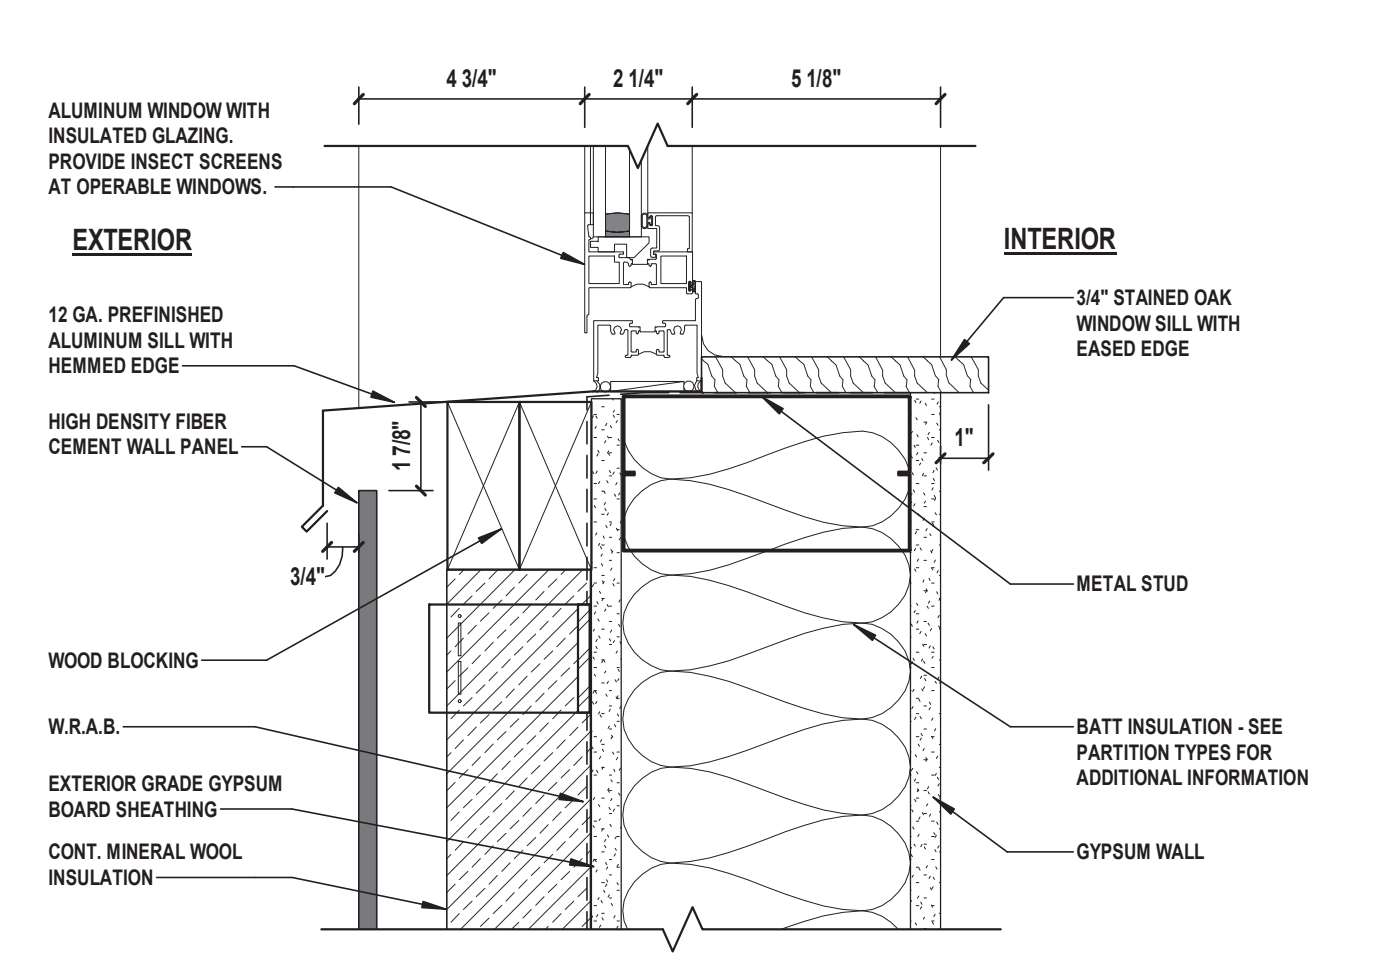

WS1 Window Sill Detail
SCALE: 3" = 1'-0"

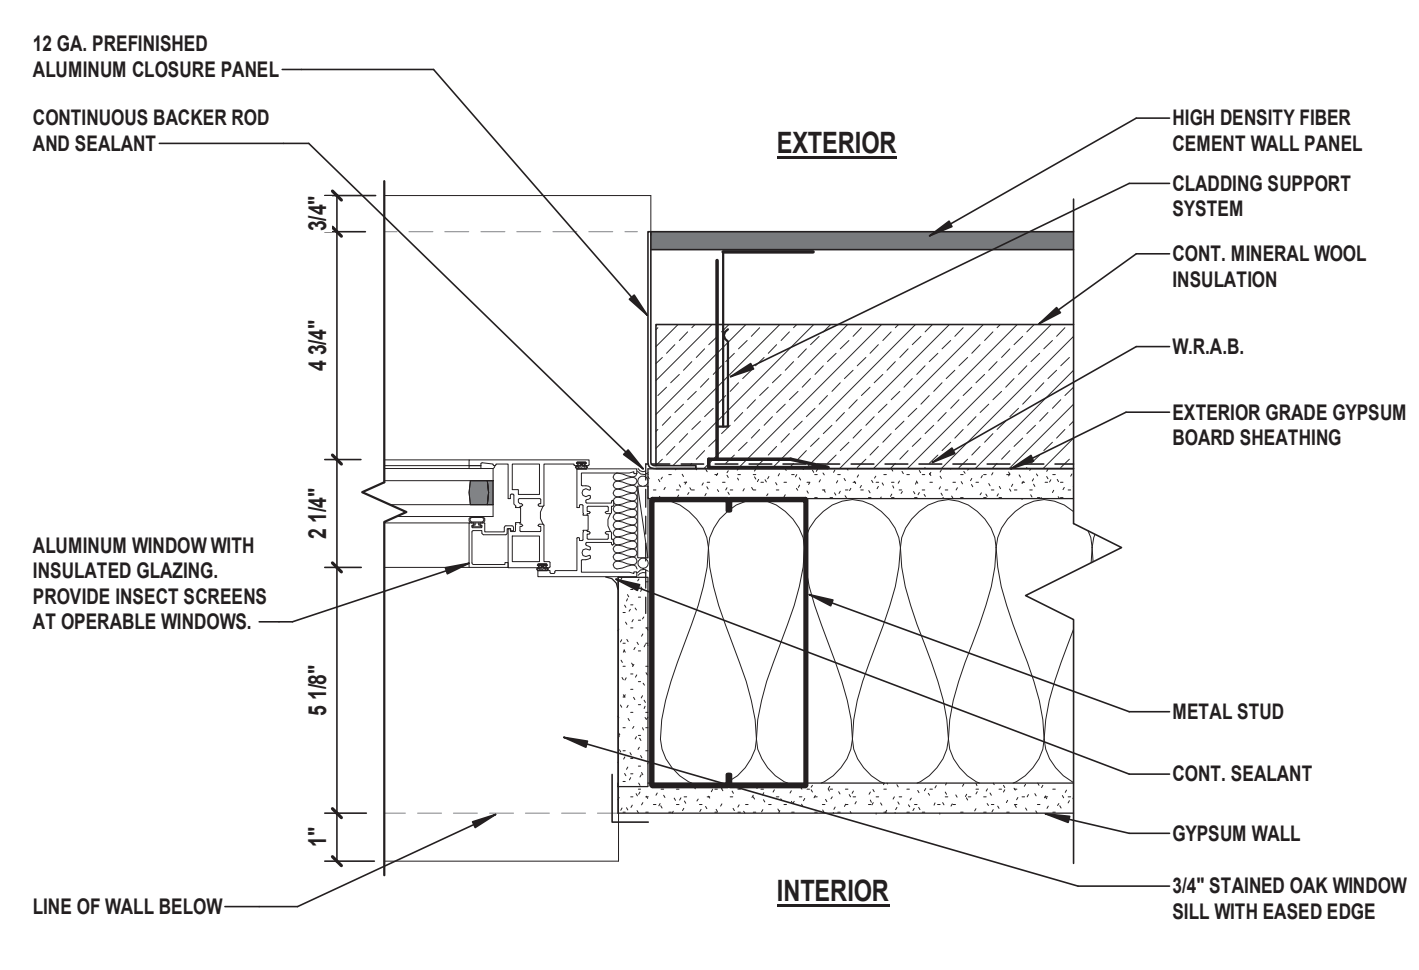

WJ1 Window Jamb Detail
SCALE: 3" = 1'-0"

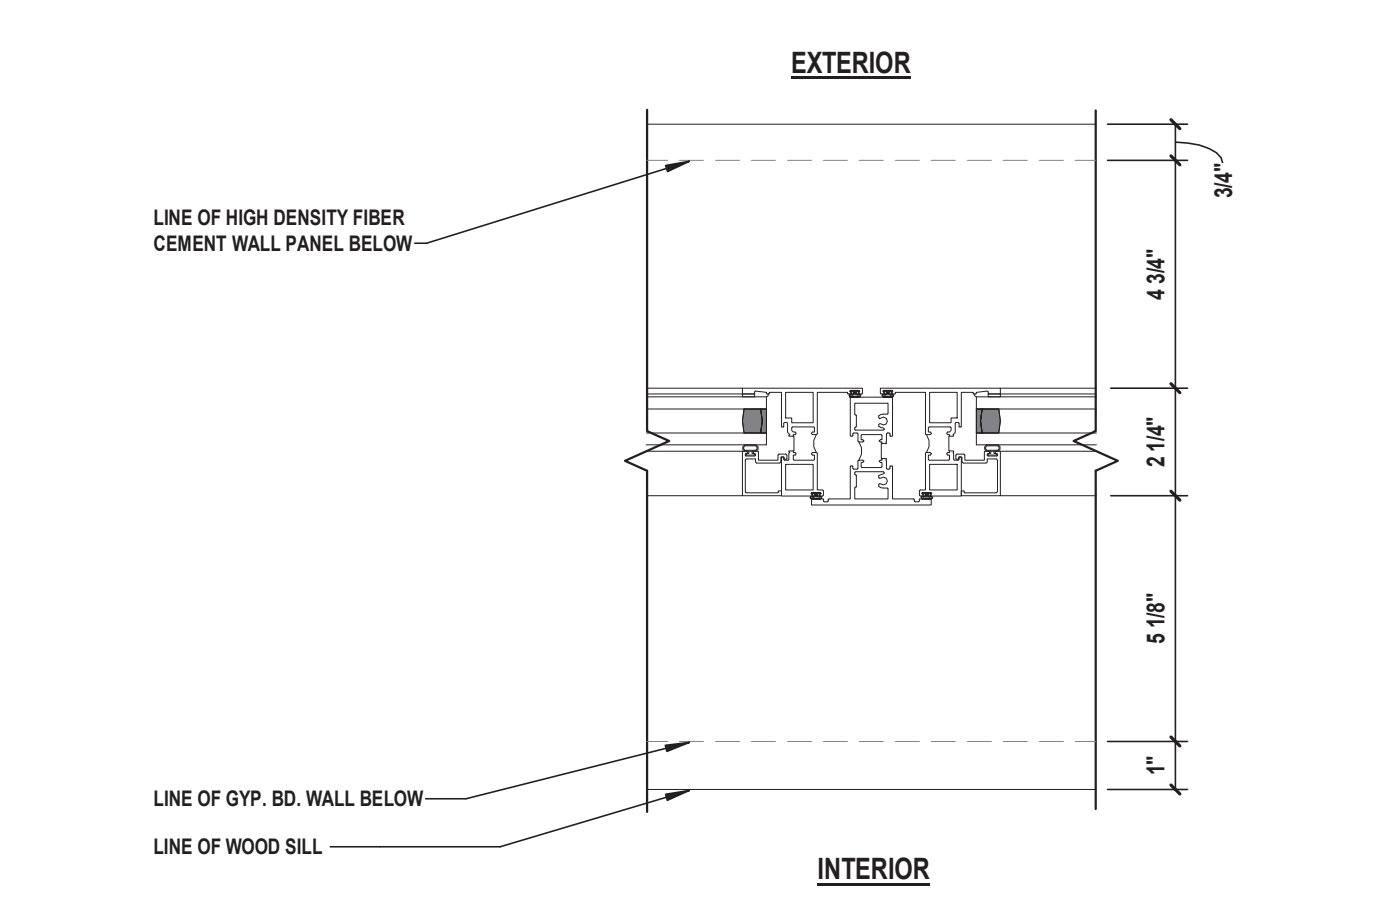

WJ2 Window Stiles Detail
SCALE: 3" = 1'-0"

THIELLS
ROSEVILLE FIRE
DISTRICT

NEW 26-100 FIRE
HEADQUARTERS



65 W RAMAPO ROAD
GARNERVILLE, NY 10923

CONTRACT
**CONTRACT G
GENERAL CONSTRUCTION**

STATUS
FINAL BID DOCUMENT

SHEET TITLE
WINDOW TYPES & DETAILS

DRAWING No.
A 610.00

FLOOR	DOOR SCHEDULE																		
	DOOR NO.	FROM ROOM		TO ROOM		DOOR SIZE	DOOR			FRAME			DETAILS			FIRE RATING	HARDWARE SET	DOOR SIGNAGE	COMMENTS
		NAME	NUMBER	NAME	NUMBER		WIDTH x HEIGHT	DOOR TYPE	DOOR MATERIAL	DOOR FINISH	FRAME TYPE	FRAME MATERIAL	FRAME FINISH	HEAD	JAMB				
FIRST FLOOR	100A	STAIR	'A'	EXTERIOR	-	(2) 36" x 84"	04	ALUM/GLASS	FF	BY MANU.	AL	FF	SEE A 630	SEE A 630	SEE A 630		1		
	100B	STAIR	'B'	EXTERIOR	-	(2) 36" x 84"	04	ALUM/GLASS	FF	BY MANU.	AL	FF	SEE A 630	SEE A 630	SEE A 630		1		
	100C	VESTIBULE	100A	EXTERIOR	-	36" x 84"	05	ALUM/GLASS	FF	F1	AL	FF	DH5	DJ5	DS3		2		
	100D	CORRIDOR	100	STAIR	'A'	36" x 84"	02	WD	FF	F1	HM	PT	DH7	DJ7	DS1	45 MIN.	19	•	
	100E	CORRIDOR	100	VESTIBULE	100A	36" x 84"	07	WD	FF	F1	HM	PT	DH7	DJ7	DS1		18		
	100F	CORRIDOR	100	STAIR	'B'	36" x 84"	02	WD	FF	F1	HM	PT	DH7	DJ7	DS1	45 MIN.	19	•	
	101	CORRIDOR	100	WOMEN'S TOILET	101	36" x 84"	01	WD	FF	F1	HM	PT	DH7	DJ7	DS2		16	•	
	101A	J.C.	101A	CORRIDOR	100	36" x 84"	09	WD	FF	F1	HM	PT	DH7	DJ7	DS2		6	•	
	102	CORRIDOR	100	CHIEFS OFFICE	102	36" x 84"	07	WD	FF	F1	HM	PT	DH7	DJ7	DS4		11		
	102A	CHIEF'S STORAGE	102A	CHIEFS OFFICE	102	36" x 84"	01	WD	FF	F1	HM	PT	DH7	DJ7	DS1		17		
	103	CORRIDOR	100	MEN'S TOILET	103	36" x 84"	01	WD	FF	F1	HM	PT	DH7	DJ7	DS2		16	•	
	104	CORRIDOR	100	CONFERENCE ROOM	104	36" x 84"	01	WD	FF	F1	HM	PT	DH7	DJ7	DS4		5	•	
	104A	CORRIDOR	100	CONFERENCE ROOM	104	36" x 84"	01	WD	FF	F1	HM	PT	DH7	DJ7	DS4		5	•	
	105	CORRIDOR	100	FITNESS ROOM	105	36" x 84"	05	ALUM/GLASS	FF	SEE A 640	AL	FF	SEE A 640	SEE A 640	DS4		13	•	
	105A	FITNESS ROOM	105	SHOWER ROOM	105A	36" x 84"	01	WD	FF	F1	HM	PT	DH7	DJ7	DS2		15	•	
	105B	FITNESS ROOM	105	EXTERIOR	-	(2) 36" x 84"	04	ALUM/GLASS	FF	SEE A 640	AL	FF	SEE A 640	SEE A 640	DS3		1		
	106	CORRIDOR	100	LINE OFFICERS	106	36" x 84"	07	WD	FF	F1	HM	PT	DH7	DJ7	DS4		11	•	
	107	CORRIDOR	100	DAY ROOM	107	36" x 84"	07	WD	FF	F1	HM	PT	DH7	DJ7	DS7		6	•	
	107A	DAY ROOM	107	EXTERIOR	-	36" x 84"	05	ALUM/GLASS	FF	SEE A 640	AL	FF	SEE A 640	SEE A 640	DS3		2		
	108	CORRIDOR	100	UNIFORM STORAGE	108	36" x 84"	01	WD	FF	F1	HM	PT	DH7	DJ7	DS7		6	•	
	109	CORRIDOR	100	WOMEN'S AUXILARY	109	36" x 84"	01	WD	FF	F1	HM	PT	DH7	DJ7	DS7		11	•	
	110	UTILITY ROOM	110	STAIR	'B'	36" x 84"	01	WD	FF	F1	HM	PT	DH7	DJ7	DS7	45 MIN.	19	•	
	111	CORRIDOR	100	DECON TRANSITION	111	36" x 84"	07	HM	PT	F2	HM	PT	DH3	DJ3	DS5		20	•	
	111A	GEAR AREA	112	DECON TRANSITION	111	48" x 88"	-	-	-	-	-	-	DH8	DJ8	-		-		MASONRY OPENING
	112A	GEAR AREA	112	EXTERIOR	-	36" x 84"	02	HM	PT	F2	HM	PT	DH1	DJ1	DS3		3		
	112B	GEAR AREA	112	APPARATUS BAY	120	48" x 88"	-	-	-	-	-	-	DH8	DJ8	-		-		MASONRY OPENING
	112C	GEAR AREA	112	APPARATUS BAY	120	48" x 88"	-	-	-	-	-	-	DH8	DJ8	-		-	•	MASONRY OPENING
	112D	GEAR AREA	112	APPARATUS BAY	120	48" x 88"	-	-	-	-	-	-	DH8	DJ8	-		-		MASONRY OPENING
	112E	GEAR AREA	112	APPARATUS BAY	120	48" x 88"	-	-	-	-	-	-	DH8	DJ8	-		-	•	MASONRY OPENING
	112F	APPARATUS BAY	120	STAIR	'C'	48" x 88"	-	-	-	-	-	-	(SIM.) DH8	(SIM.) DJ8	-		-	•	MASONRY OPENING
	113	DECON BATHROOM	113	GEAR AREA	112	36" x 84"	01	HM	PT	F2	HM	PT	DH4	DJ4	DS1		15	•	
	114	GEAR AREA	112	OUTDOOR STORAGE	114	(2) 36" x 84"	10	HM	PT	F2	HM	PT	DH4	DJ4	DS1		8	•	
	115	GEAR AREA	112	LAUNDRY	115	36" x 84"	02	HM	PT	F2	HM	PT	DH4	DJ4	DS1		6	•	
	115A	LAUNDRY	115	EXTERIOR	-	(2) 36" x 84"	03	HM	PT	F2	HM	PT	DH1	DJ1	DS3		23		
	116	FIRE GEAR STORAGE	116	GEAR AREA	112	36" x 84"	01	HM	PT	F2	HM	PT	DH4	DJ4	DS1		6	•	
	117A	APPARATUS BAY	120	WORK ROOM	117	48" x 88"	-	-	--	-	-	-	DH8	DJ8	-		-	•	MASONRY OPENING
	118	APPARATUS BAY	120	DECON TRANSITION	118	48" x 88"	-	-	-	-	-	-	DH8	DJ8	-		-		MASONRY OPENING
	118A	DECON TRANSITION	118	CORRIDOR	100	36" x 84"	07	HM	PT	F2	HM	PT	DH3	DJ3	DS5		20	•	
	119	DECON TRANSITION	118	RADIO ROOM	119	36" x 84"	07	HM	PT	F2	HM	PT	DH3	DJ3	DS5		12	•	
	120	APPARATUS BAY	120	EXTERIOR	-	36" x 84"	02	HM	PT	F2	HM	PT	DH2	DH2	DS3		3		
	121	APPARATUS BAY	120	SCBA	121	(2) 36" x 84"	03	HM	PT	F2	HM	PT	DH4	DJ4	DS1		8	•	
	122	DELIVERY	122	EXTERIOR	-	36" x 84"	01	HM	PT	F1	HM	PT	DH5	DJ5	DS3		4		
	122A	CORRIDOR	100	DELIVERY	122	36" x 84"	01	WD	FF	F1	HM	PT	DH7	DJ7	DS5		25	•	
	OH-1	APPARATUS BAY	120	EXTERIOR	-	168" x 168"	11	ALUM/GLASS	FF	BY MANU.	AL	FF	2 / A 623	5 / A 623	8 / A 623		-		ADD ALTERNATE G-01
	OH-2	APPARATUS BAY	120	EXTERIOR	-	168" x 168"	11	ALUM/GLASS	FF	BY MANU.	AL	FF	2 / A 623	5 / A 623	8 / A 623		-		ADD ALTERNATE G-01
	OH-3	APPARATUS BAY	120	EXTERIOR	-	168" x 168"	11	ALUM/GLASS	FF	BY MANU.	AL	FF	2 / A 623	5 / A 623	8 / A 623		-		ADD ALTERNATE G-01
	OH-4	APPARATUS BAY	120	EXTERIOR	-	168" x 168"	11	ALUM/GLASS	FF	BY MANU.	AL	FF	2 / A 623	5 / A 623	8 / A 623		-		ADD ALTERNATE G-01
	OH-5	APPARATUS BAY	120	EXTERIOR	-	168" x 168"	11	ALUM/GLASS	FF	BY MANU.	AL	FF	2 / A 623	5 / A 623	8 / A 623		-		ADD ALTERNATE G-01
	OH-6	APPARATUS BAY	120	EXTERIOR	-	168" x 168"	12	ALUM/GLASS	FF	BY MANU.	AL	FF	1 / A 623	4 / A 623	7 / A 623		-		
	OH-7	APPARATUS BAY	120	EXTERIOR	-	168" x 168"	12	ALUM/GLASS	FF	BY MANU.	AL	FF	1 / A 623	4 / A 623	7 / A 623		-		
MEZZ.	M01	STORAGE	M01	APPARATUS BAY	120	(2) 36" x 84"	08	HM	PT	F2	HM	PT	3 / A 623	(SIM.) DJ4	6 / A 623		7	•	DOUBLE DOOR WITH SAFETY GATE
	M02	STORAGE	M01	UTILITY	M02	36" x 84"	09	HM	PT	F1	HM	PT	DH7	DJ7	DS1		6	•	
	M03	STORAGE	M01	FILE STORAGE	M03	36" x 84"	01	HM	PT	F1	HM	PT	DH7	DJ7	DS1		6	•	
	M04	STORAGE	M01	I.T.	M04	36" x 84"	01	HM	PT	F1	HM	PT	DH7	DJ7	DS1		6	•	
SECOND FLOOR	200A	CORRIDOR	200	STAIR	'A'	36" x 84"	02	WD	FF	F1	HM	PT	DH7	DJ7	DS1	45 MIN.	21	•	MAGNETIC HOLD OPENS TIED INTO FIRE ALARM SYSTEM, SEE 'FA' DRAWINGS
	200B	CORRIDOR	200	STAIR	'B'	(2) 36" x 84"	06	WD	FF	F1	HM	PT	DH7	DJ7	DS1	45 MIN.	22	•	MAGNETIC HOLD OPENS TIED INTO FIRE ALARM SYSTEM, SEE 'FA' DRAWINGS
	201	CORRIDOR	200	KITCHEN	201	(2) 36" x 84"	06	WD	FF	F1	HM	PT	DH7	DJ7	DS6		10	•	
	201A	KITCHEN	201	PANTRY	201A	36" x 84"	01	WD	FF	F1	HM	PT	DH7	DJ7	DS1		6	•	
	201B	KITCHEN	201	MULTI-PURPOSE ROOM	203	36" x 84"	07	WD	FF	F1	HM	PT	DH6	DJ6	DS2		24	•	DOUBLE ACTING DOOR
	202	COMMISSIONERS	202	CORRIDOR	200	36" x 84"	07	WD	FF	F1	HM	PT	DH7	DJ7	DS4		11	•	
	203A	MULTI-PURPOSE ROOM	203A	STAIR	'B'	36" x 84"	02	WD	FF	F1	HM	PT	DH7	DJ7	DS4	45 MIN.	18	•	
	203B	MULTI-PURPOSE ROOM	203	CORRIDOR	200	(2) 36" x 84"	08	WD	FF	F1	HM	PT	DH7	DJ7	DS4		14	•	PROVIDE APPLIED DECORATIVE WINDOW FILM FULL SIZE OF VISION LITE
	203C	MULTI-PURPOSE ROOM	203	CORRIDOR	200	(2) 36" x 84"	08	WD	FF	F1	HM	PT	DH7	DJ7	DS4		14	•	PROVIDE APPLIED DECORATIVE WINDOW FILM FULL SIZE OF VISION LITE
	204	MULTI-PURPOSE STORAGE	204	MULTI-PURPOSE ROOM	203	(2) 36" x 84"	03	WD	FF	F1	HM	PT	DH7	DJ7	DS1		9	•	
	205	PURCHASING	205	CORRIDOR	200	36" x 84"	07	WD	FF	F1	HM	PT	DH7	DJ7	DS4		11	•	
	206	PRESIDENTS	206	CORRIDOR	200	36" x 84"	07	WD	FF	F1	HM	PT	DH7	DJ7	DS4		11	•	
	207	W. TOILET	207	CORRIDOR	200	36" x 84"	01	WD	FF	F1	HM	PT	DH7	DJ7	DS2		16	•	
	208	J.C.	208	CORRIDOR	200	36" x 84"	09	WD	FF	F1	HM	PT	DH7	DJ7	DS2		6	•	
	209	M. TOILET	209	CORRIDOR	200	36" x 84"	01	WD	FF	F1	HM	PT	DH7	DJ7	DS2		16	•	
ABBREVIATIONS																			
ALUM = ALUMINUM FF = FACTORY FINISH HM = HOLLOW METAL PT = PAINT ST = STAIN WD = WOOD DOOR • = DENOTES TO BE PROVIDED																			

- GENERAL DOOR NOTES
1.

ALL DOOR FRAMES TO BE SET 4" @ METAL STUD PARTITIONS AND 8" @ CMU PARTITIONS FROM ADJACENT FINISHED WALL SURFACE AND UNLESS DIMENSIONED OR NOTED OTHERWISE.
2.


ALL GLASS LITES IN DOORS, INCLUDING SITE LITES, SHALL BE TEMPERED SAFETY GLAZING. ALL GLASS LITES IN FIRE RATED DOORS SHALL HAVE FIRE RESISTIVE GLAZING IN ACCORDANCE WITH NFPA 80.
3.

ALL EXTERIOR DOORS ARE TO BE WEATHERSTRIPPED.
4.

ALL INTERIOR DOORS SHALL HAVE A 5/8" UNDERCUT, UNLESS NOTED OTHERWISE. UNDERCUT SHALL BE MEASURED FROM THE TOP OF THE SADDLE OR FINISHED FLOOR. CONTRACTOR TO VERIFY IN FIELD AND COORDINATE WITH FINISHES.
5.

REFER TO PROJECT MANUAL FOR HARDWARE INFORMATION.
6.

TACTILE EXIT SIGNAGE SHALL BE PROVIDED ADJACENT TO EACH DOOR SERVING AN EXIT STAIRWAY, EXIT PASSAGE OR EXIT DISCHARGE.

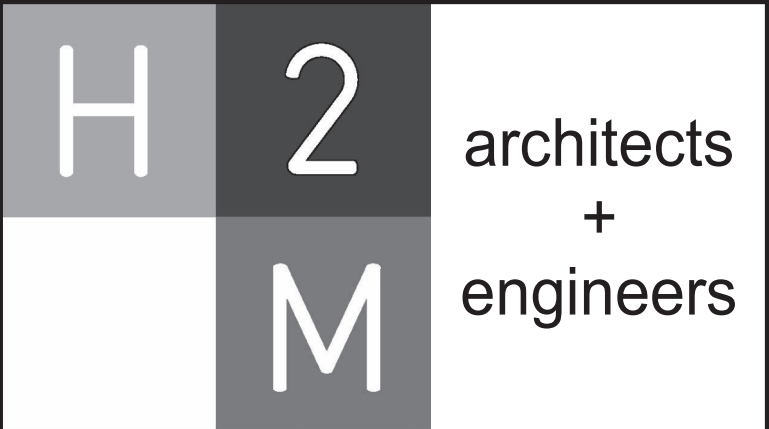

538 Broad Hollow Road, 4th Floor East
Melville, NY 11747
631.756.8000 • www.h2m.com
NY Architecture & Landscape Architecture: No Certificate Required
NY Engineering Certificate of Authorization No.: 0018178

CONSULTANTS:		

MARK	DATE	DESCRIPTION

10/31/2025

Exp. Date


PATRICK O. STONE, R.A.

NY PROFESSIONAL ARCHITECT LIC. NO. 029654


"IN ACCORDANCE WITH ARTICLE

C:\Users\skelton\Documents\TRFD2302_Central23_A_AKaled.rvt


2/25/2025 4:09:55 PM

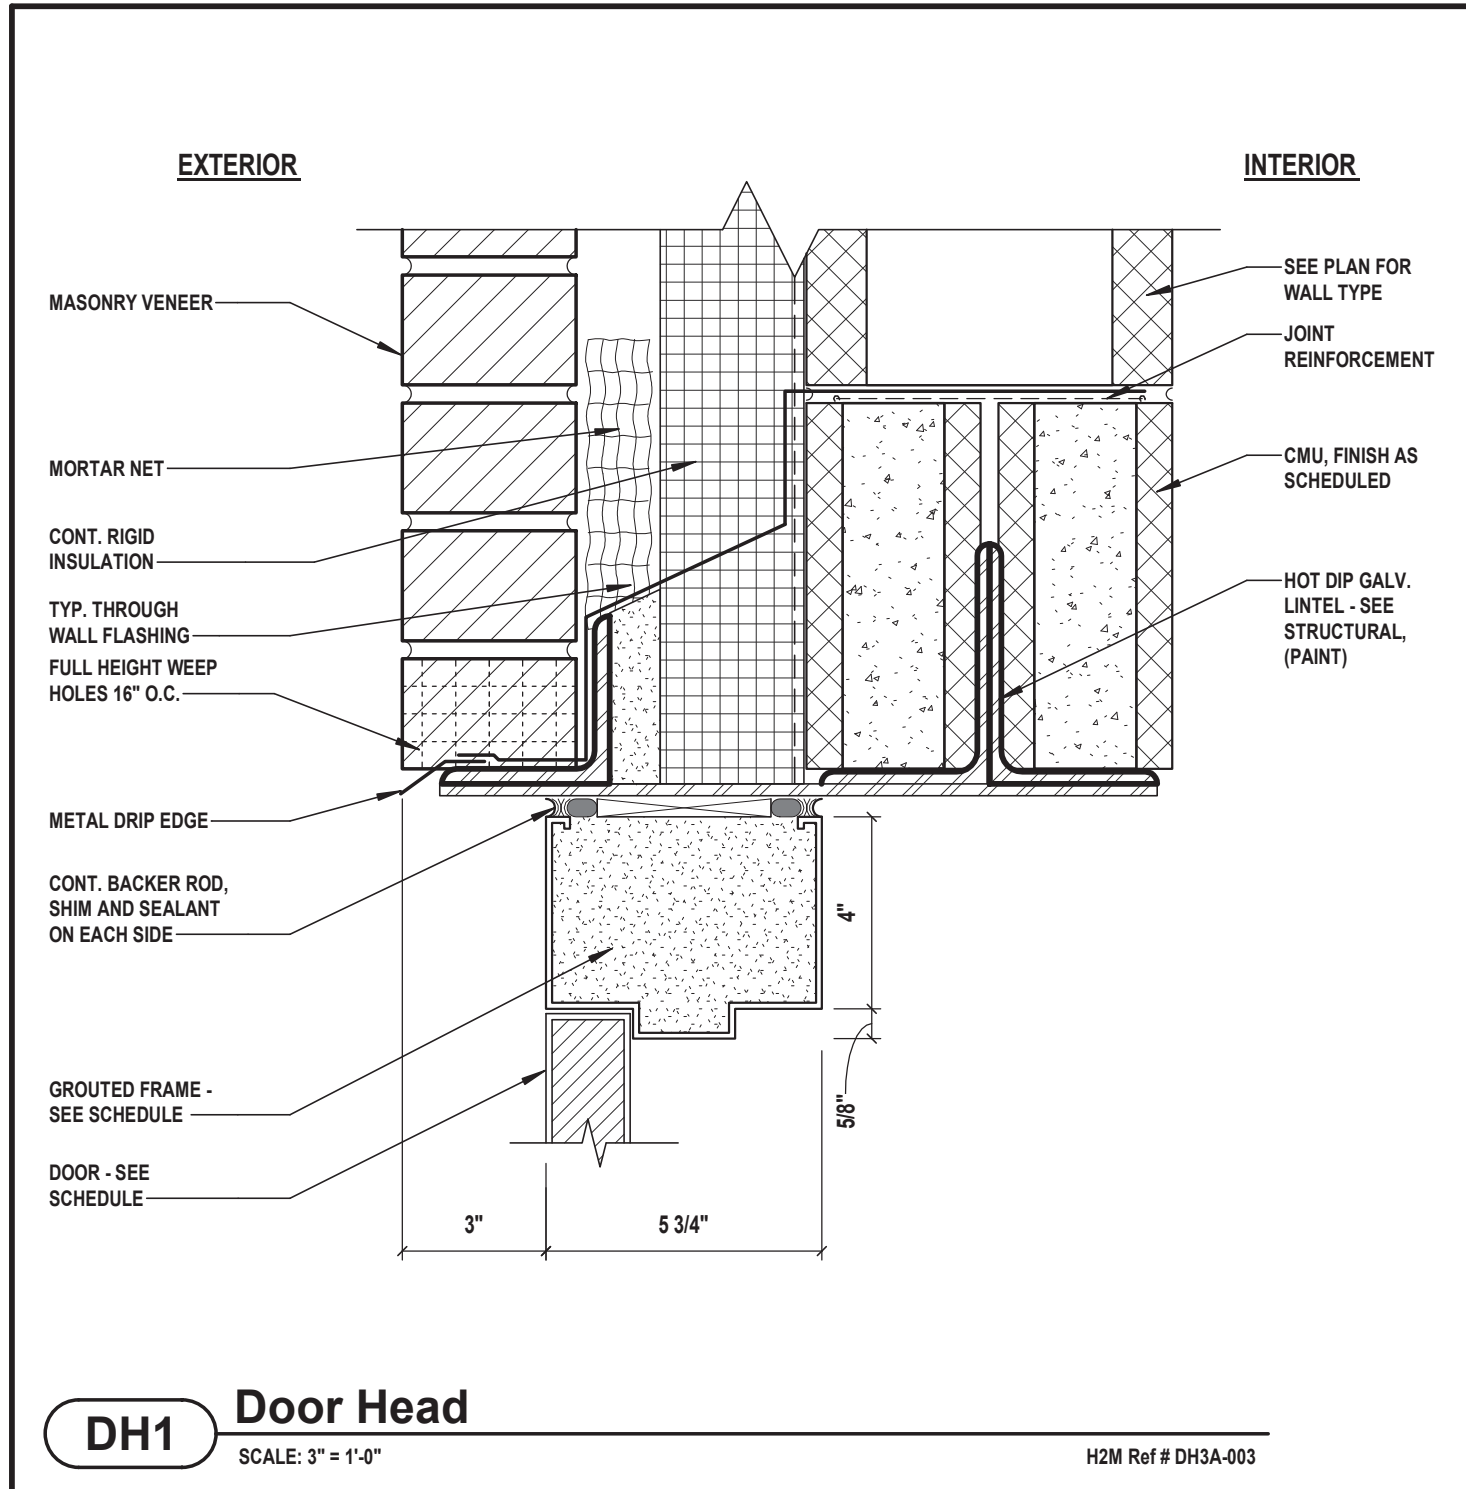


DH1 Door Head
SCALE: 3" = 1'-0"
H2M Ref # DH3A-003

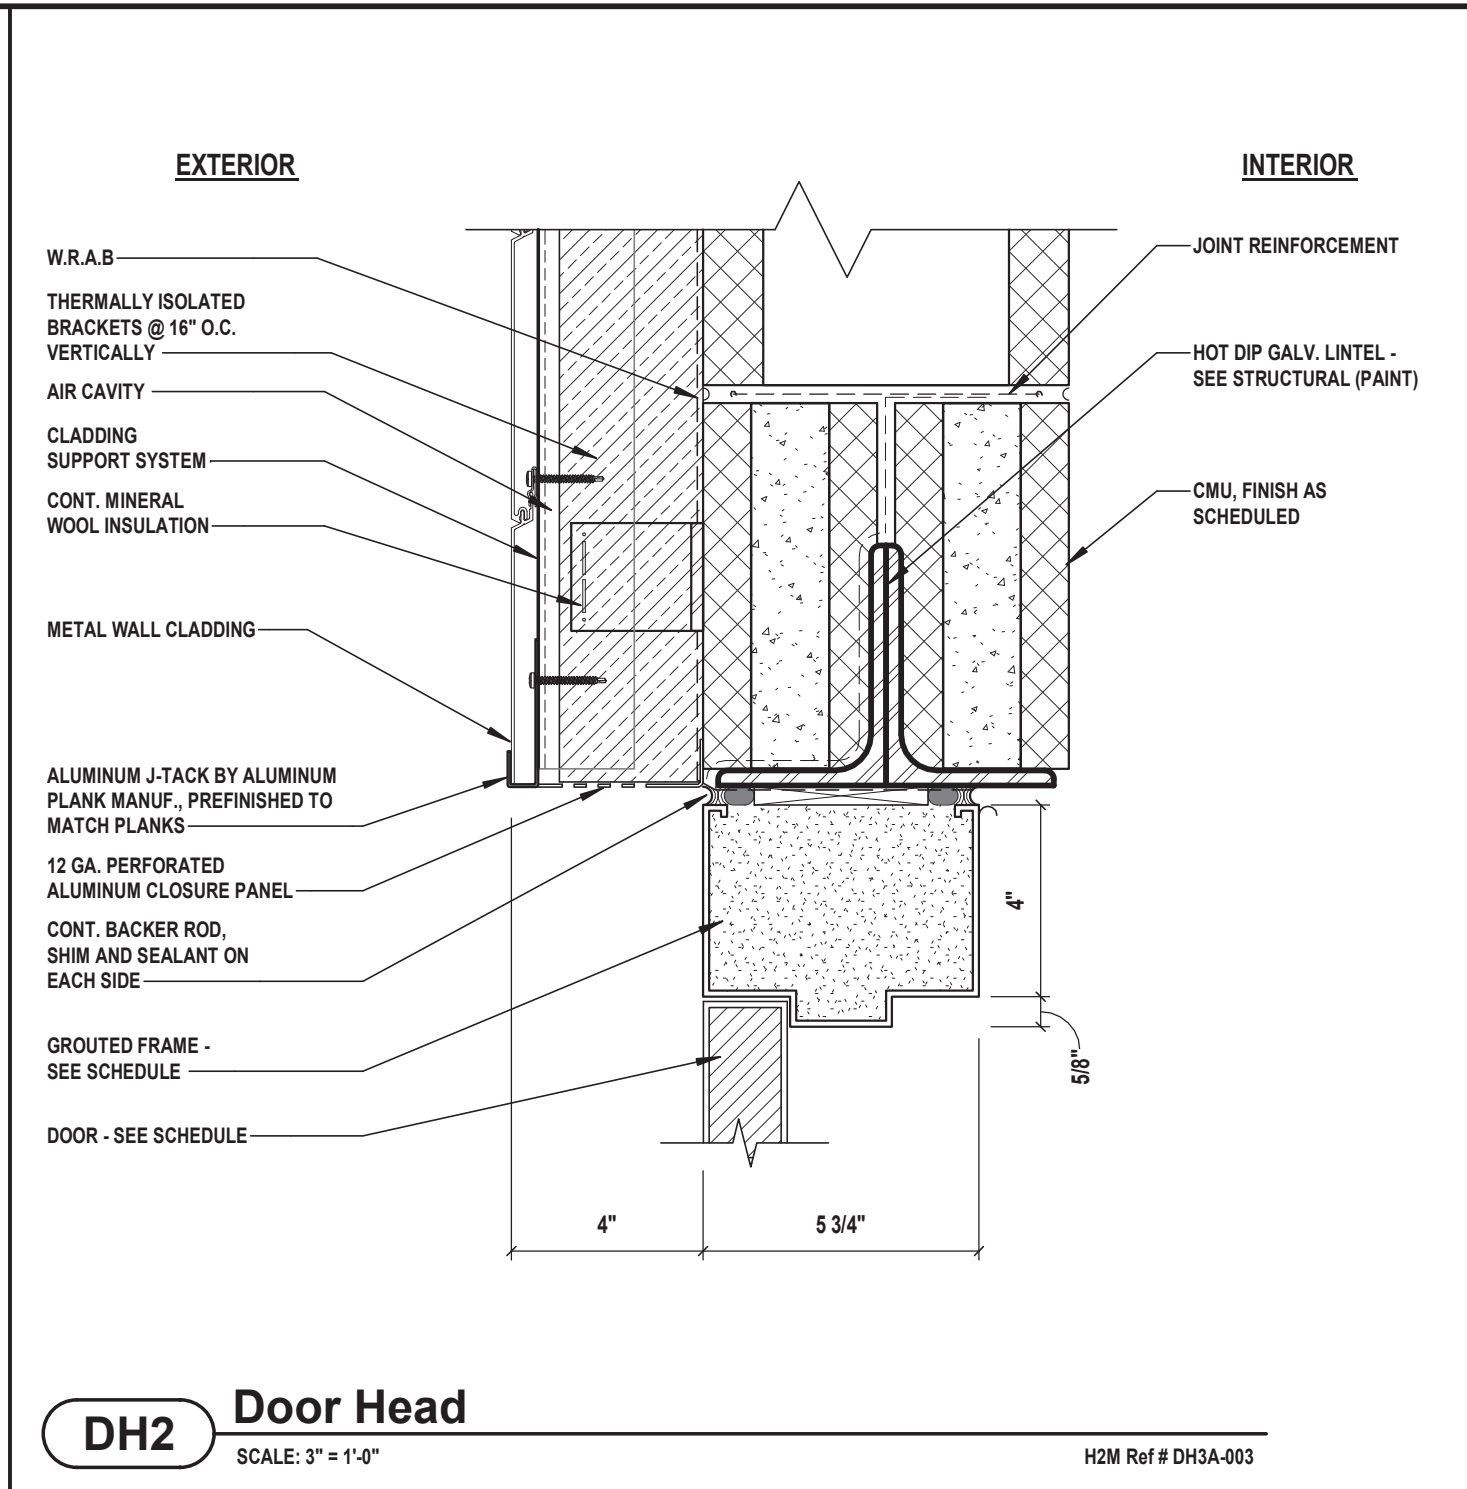


DH2 Door Head
SCALE: 3" = 1'-0"
H2M Ref # DH3A-003

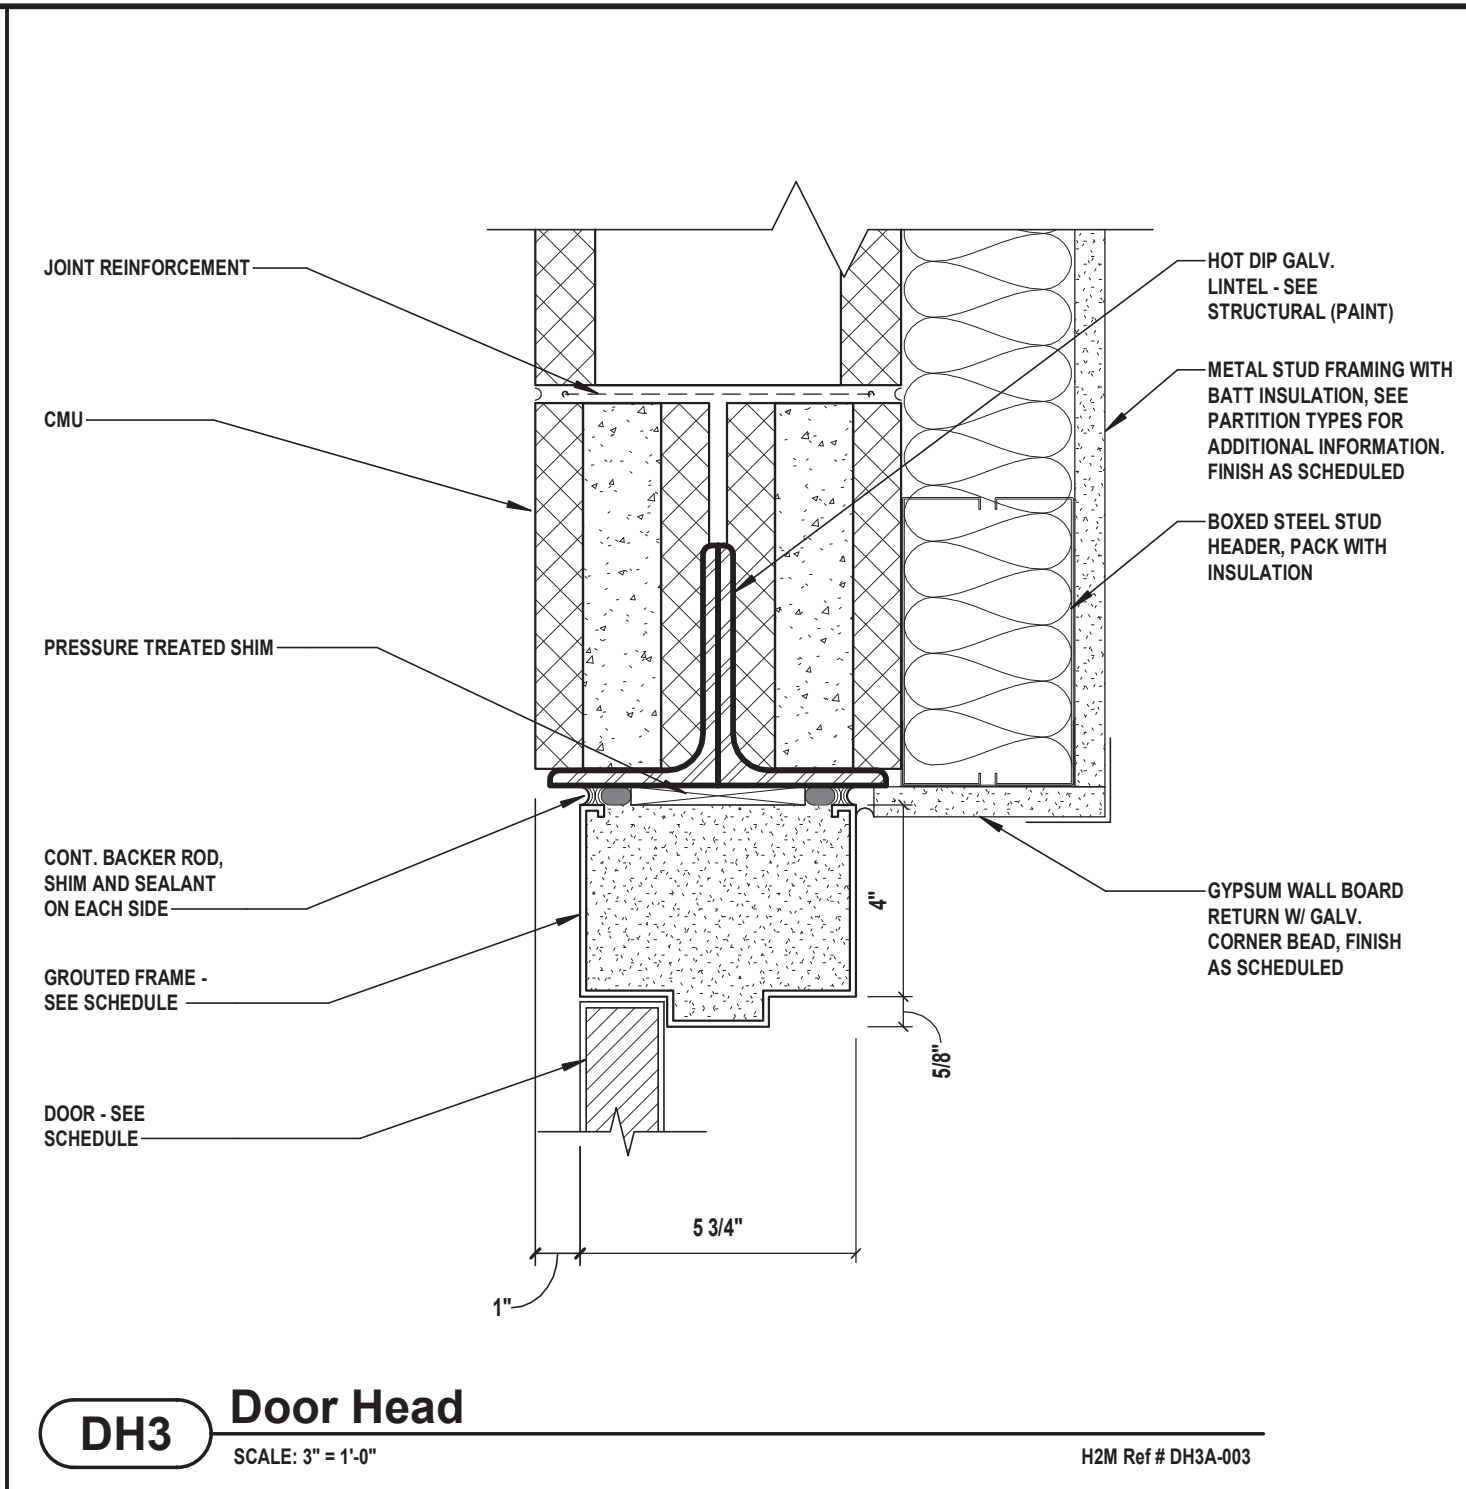


DH3 Door Head
SCALE: 3" = 1'-0"
H2M Ref # DH3A-003

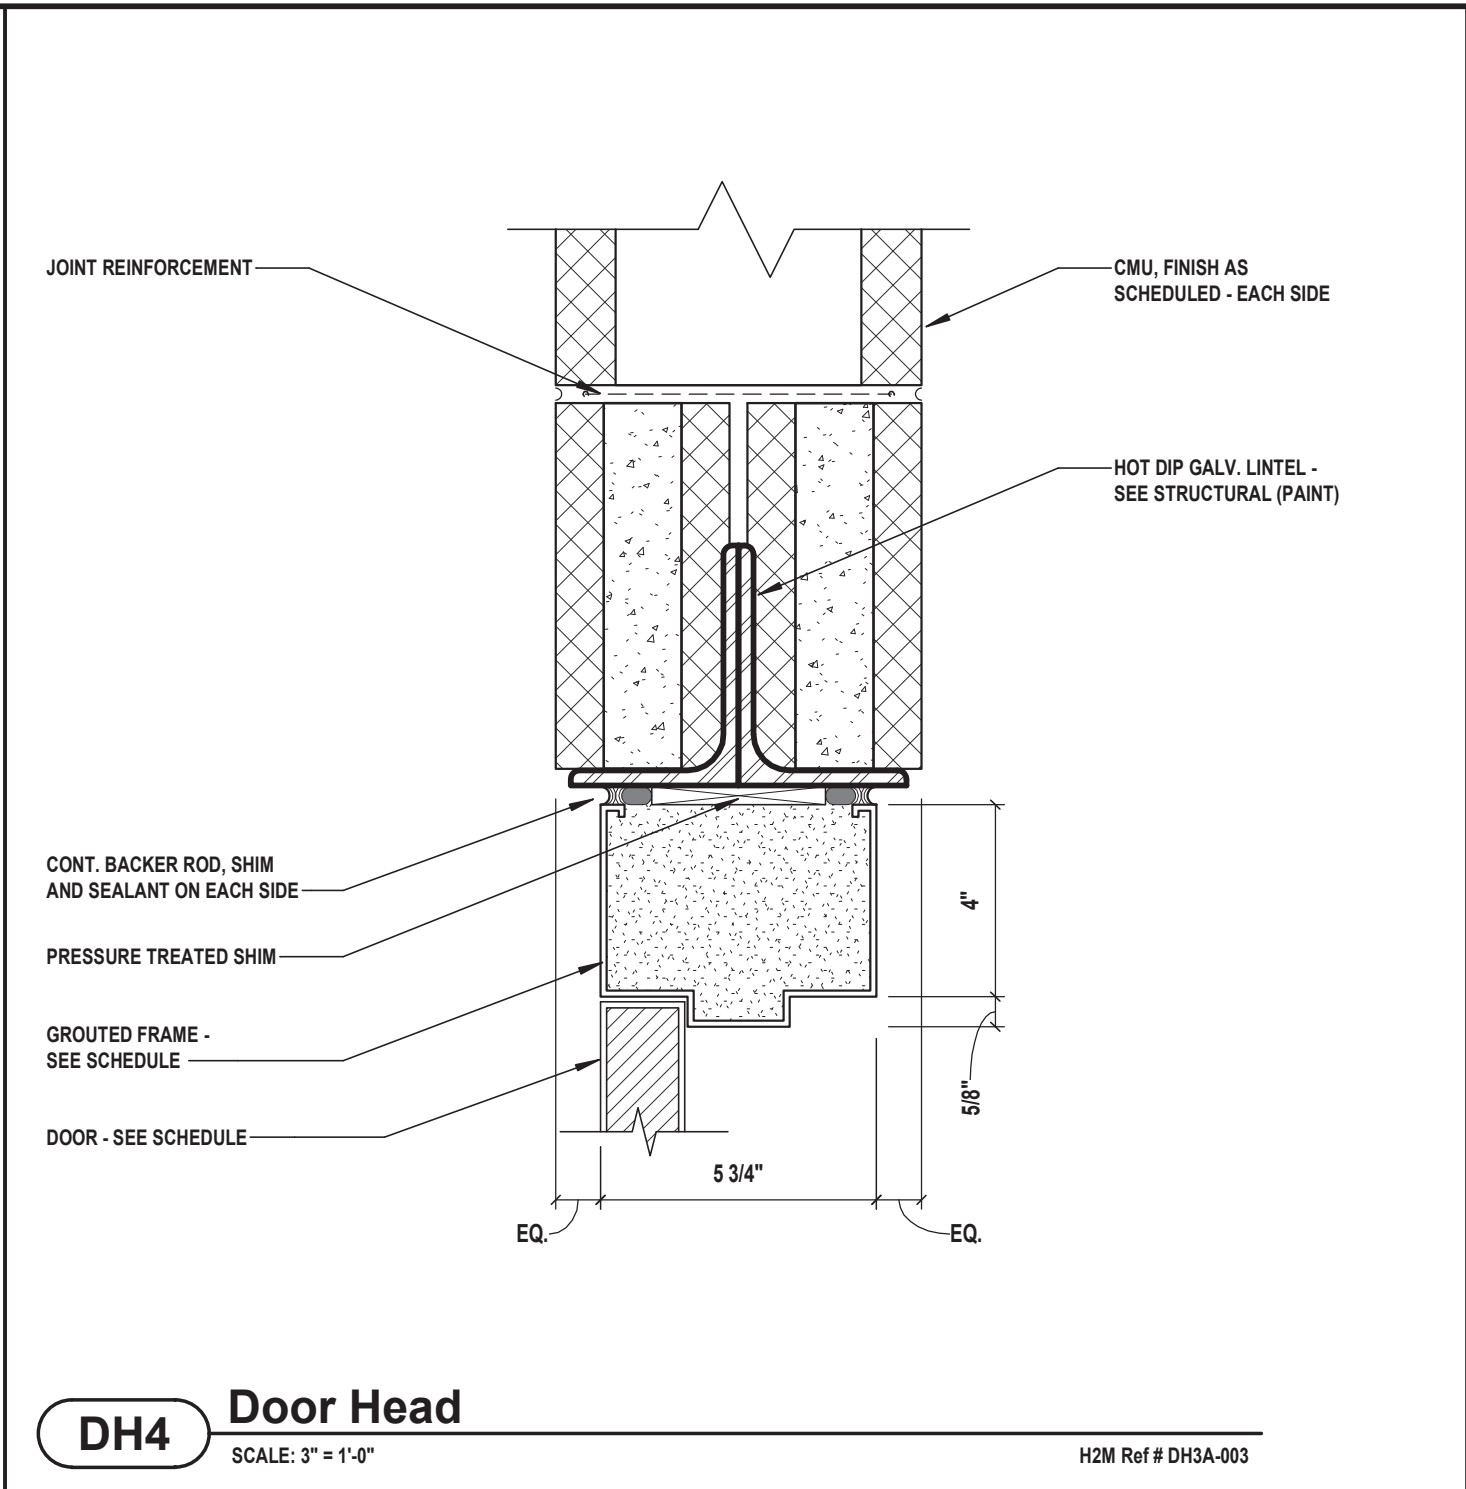


DH4 Door Head
SCALE: 3" = 1'-0"
H2M Ref # DH3A-003

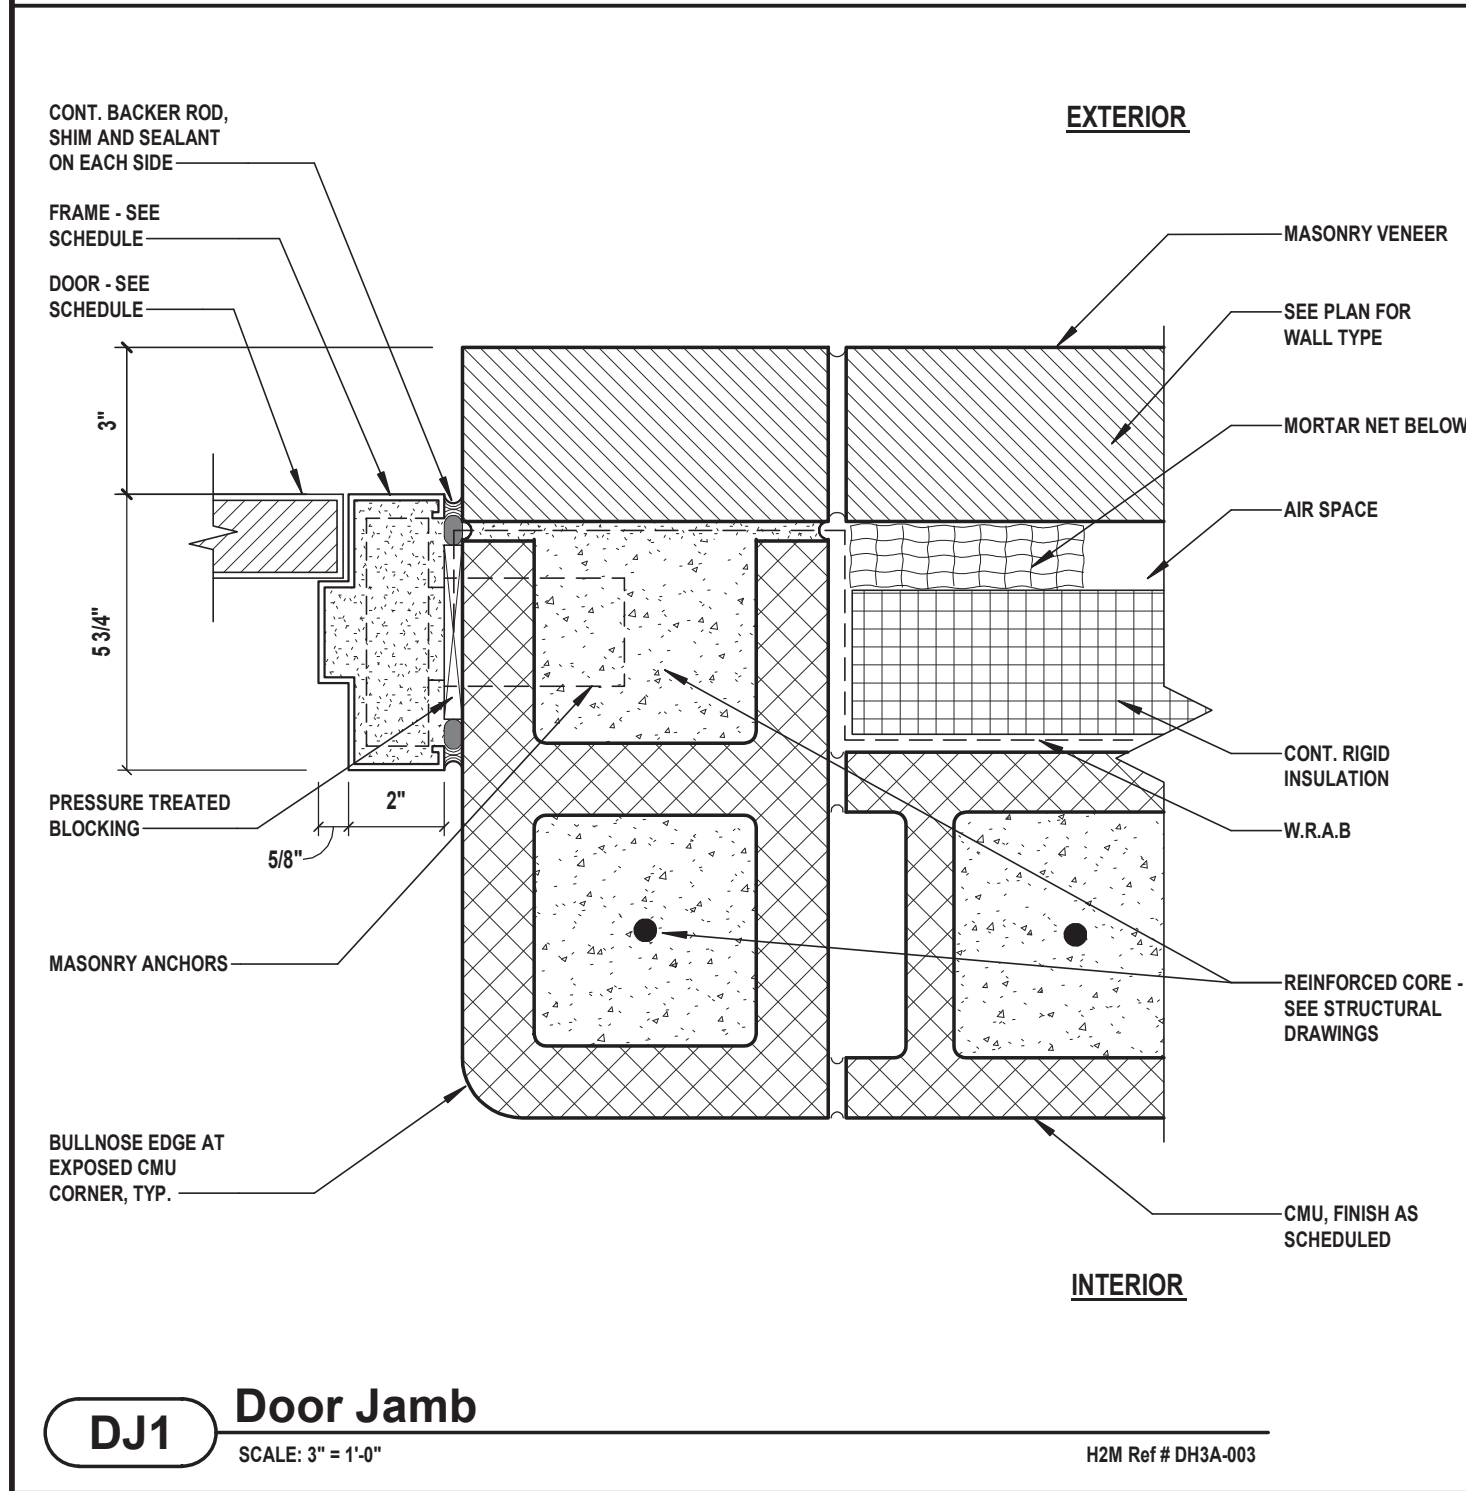


DJ1 Door Jamb
SCALE: 3" = 1'-0"
H2M Ref # DH3A-003

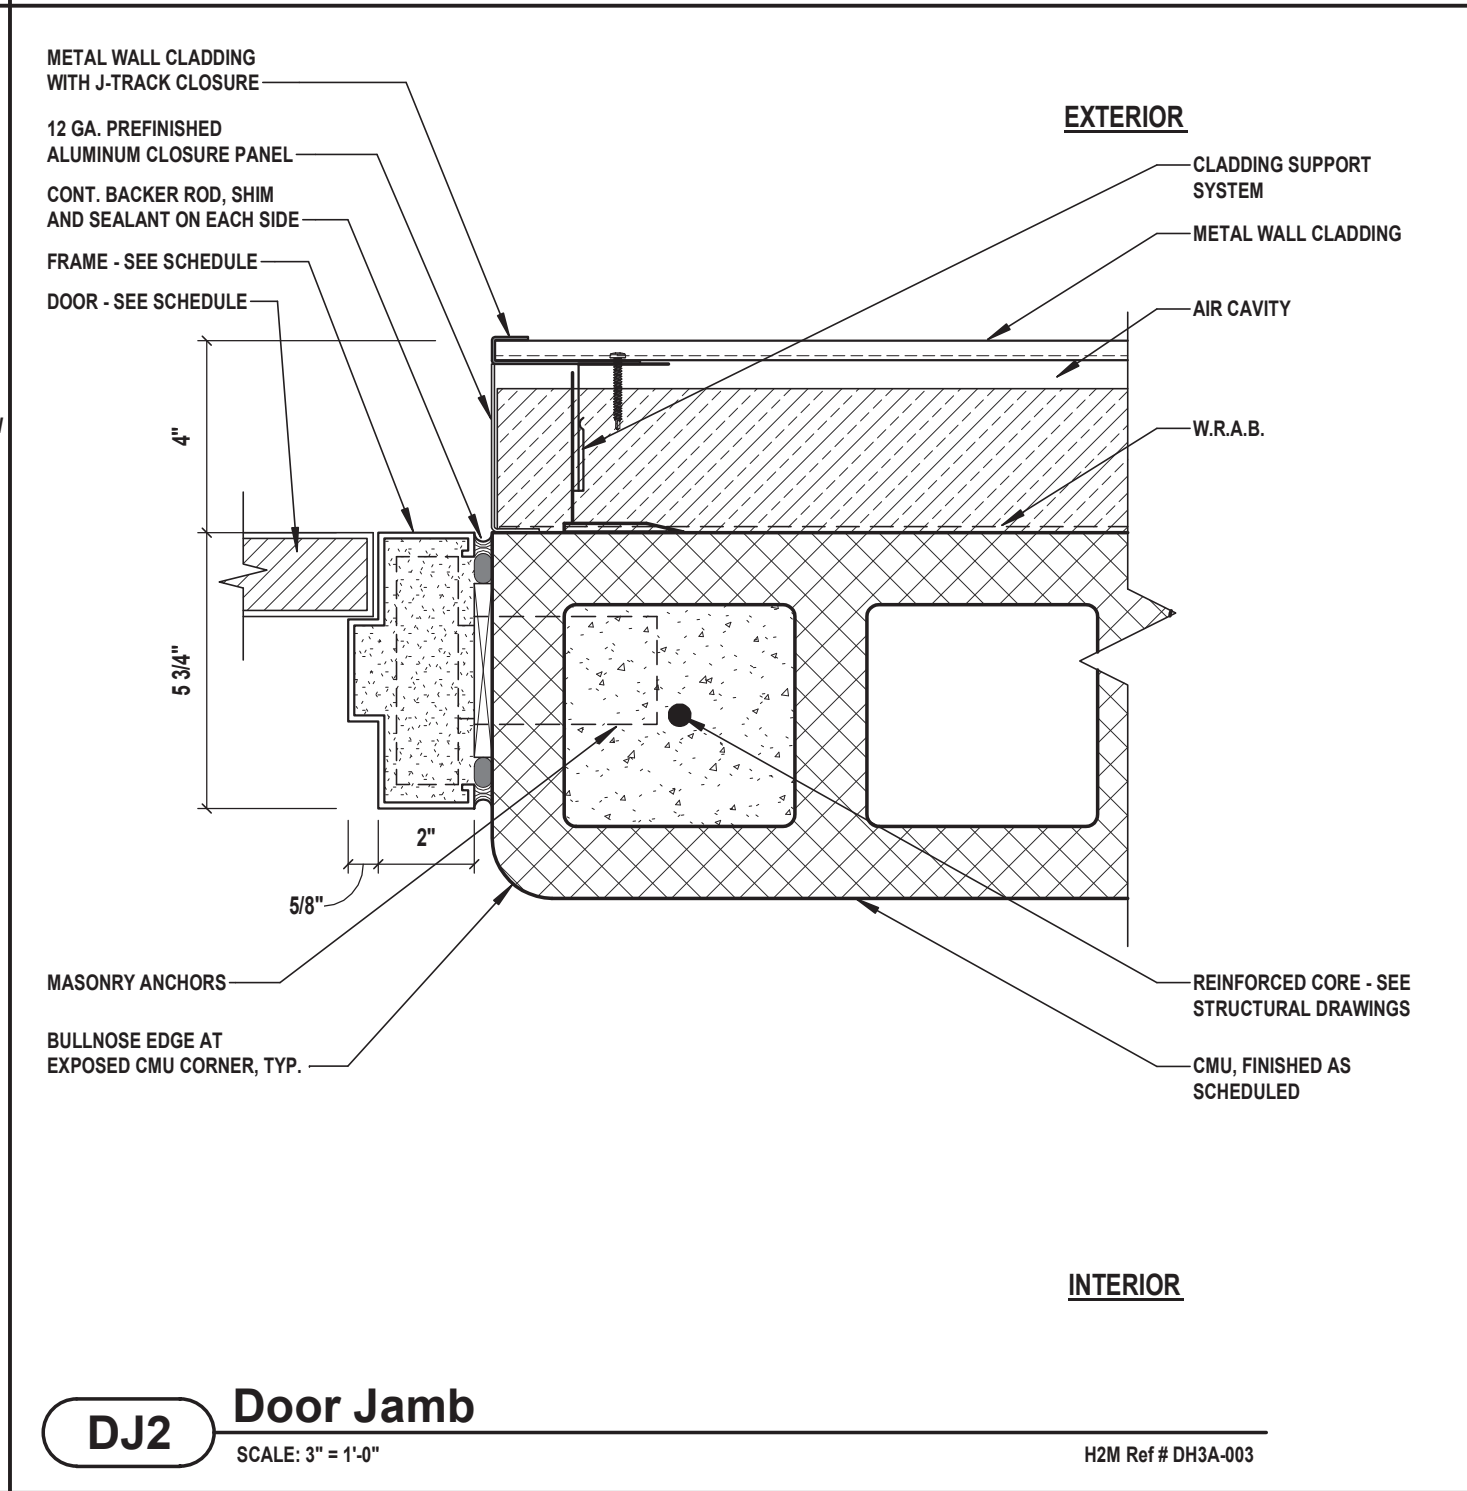



DJ2 Door Jamb
SCALE: 3" = 1'-0"
H2M Ref # DH3A-003

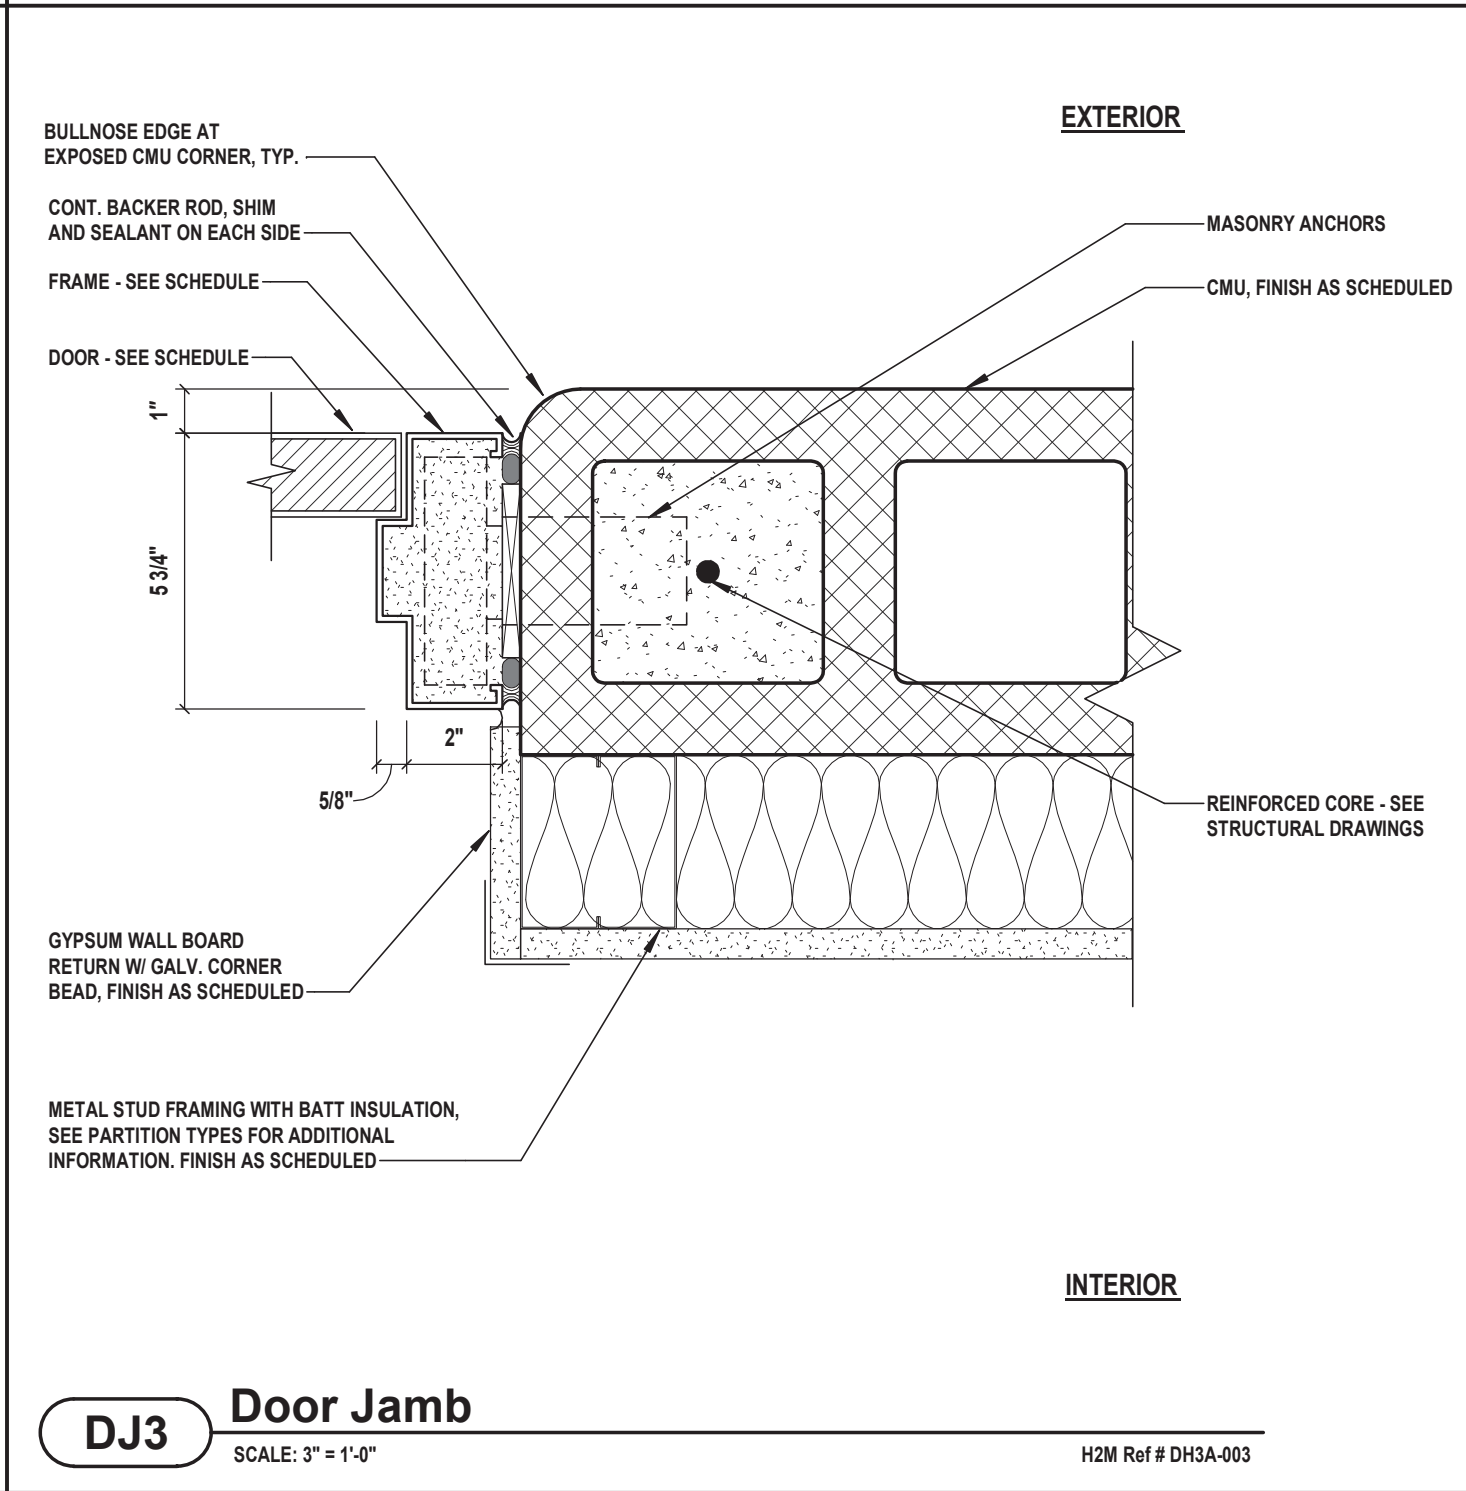


DJ3 Door Jamb
SCALE: 3" = 1'-0"
H2M Ref # DH3A-003

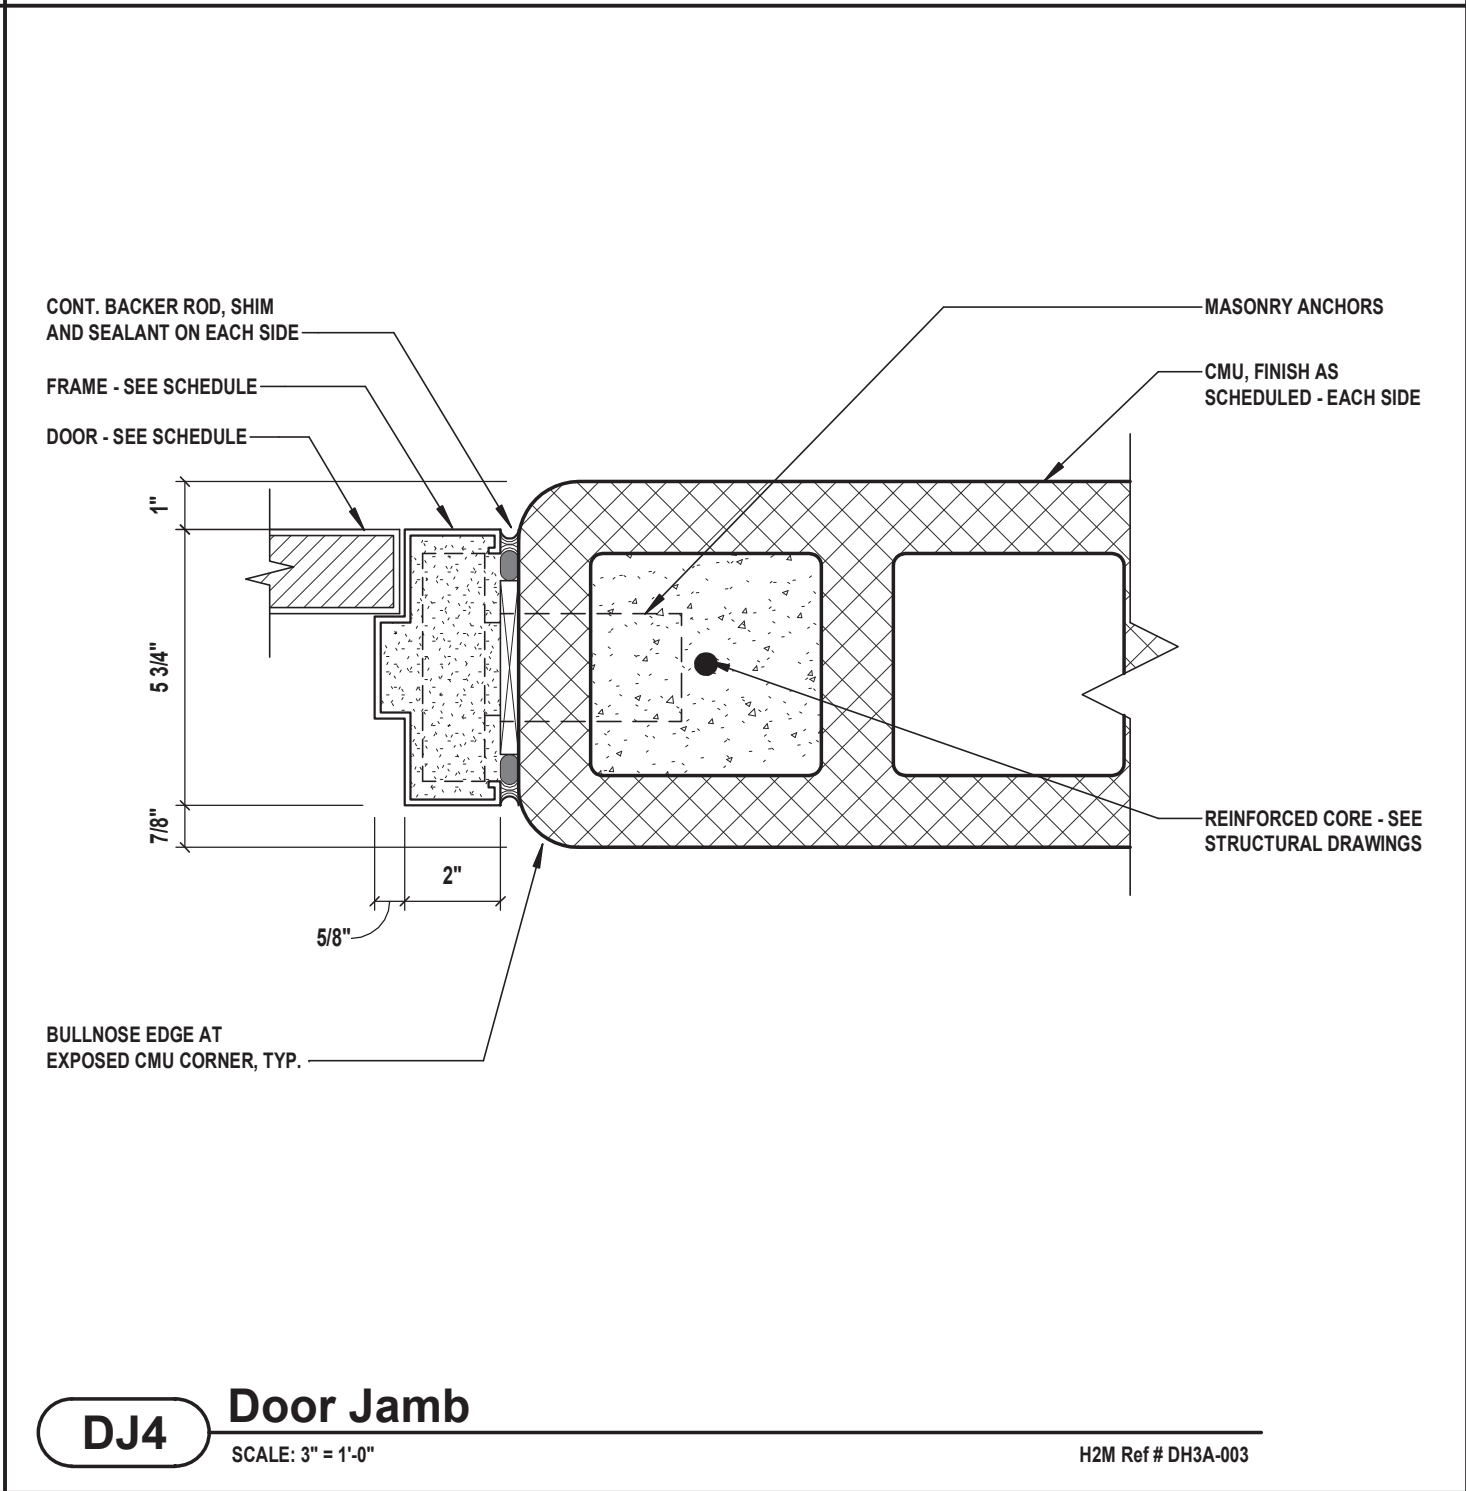

 
DJ4 Door Jamb
SCALE: 3" = 1'-0"
H2M Ref # DH3A-003

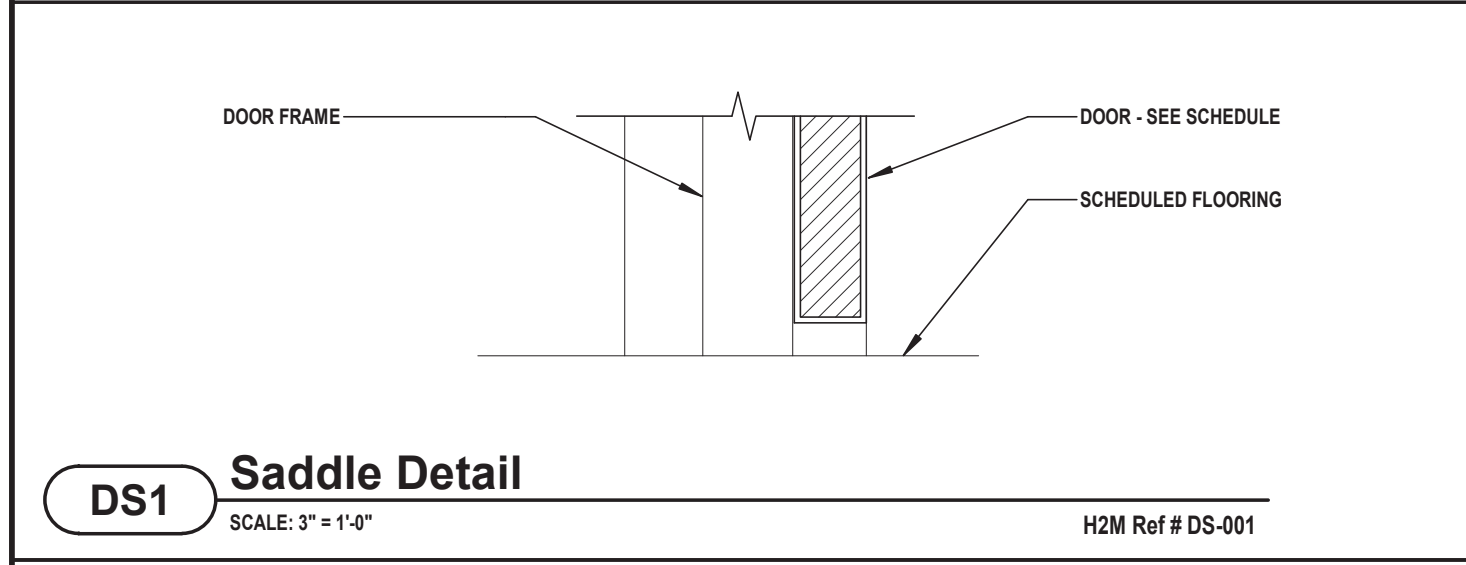


DS1 Saddle Detail
SCALE: 3" = 1'-0"
H2M Ref # DS-001

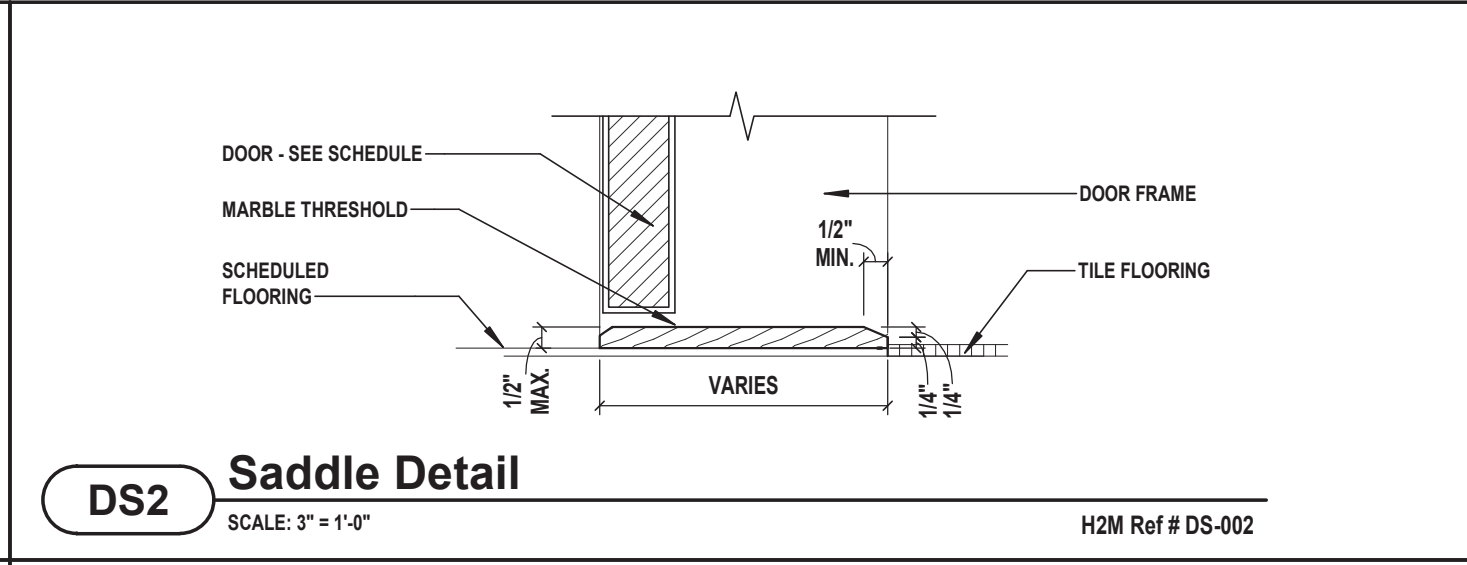


DS2 Saddle Detail
SCALE: 3" = 1'-0"
H2M Ref # DS-002

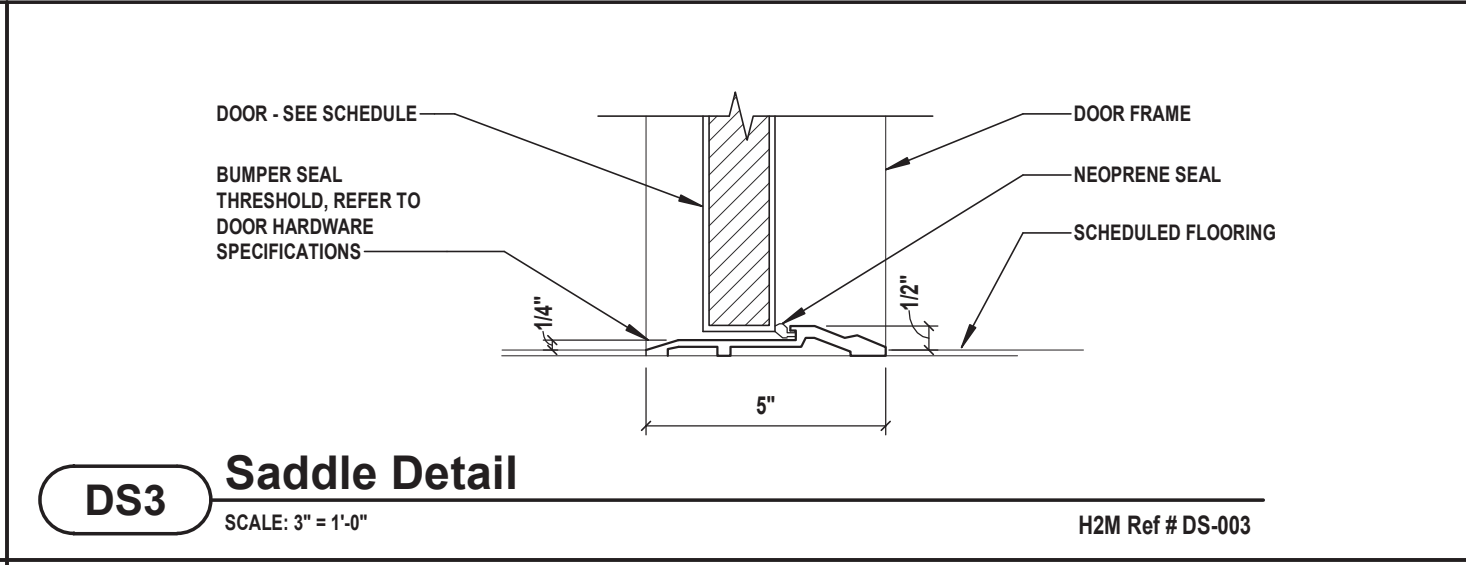


DS3 Saddle Detail
SCALE: 3" = 1'-0"
H2M Ref # DS-003

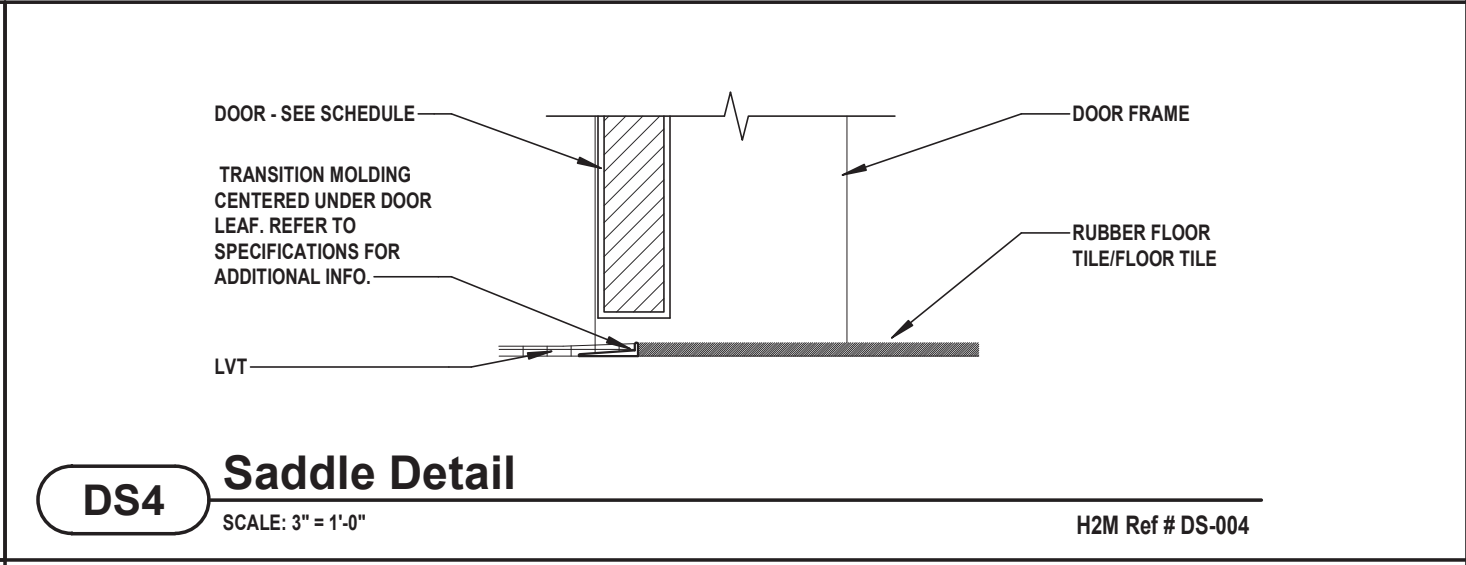


DS4 Saddle Detail
SCALE: 3" = 1'-0"
H2M Ref # DS-004

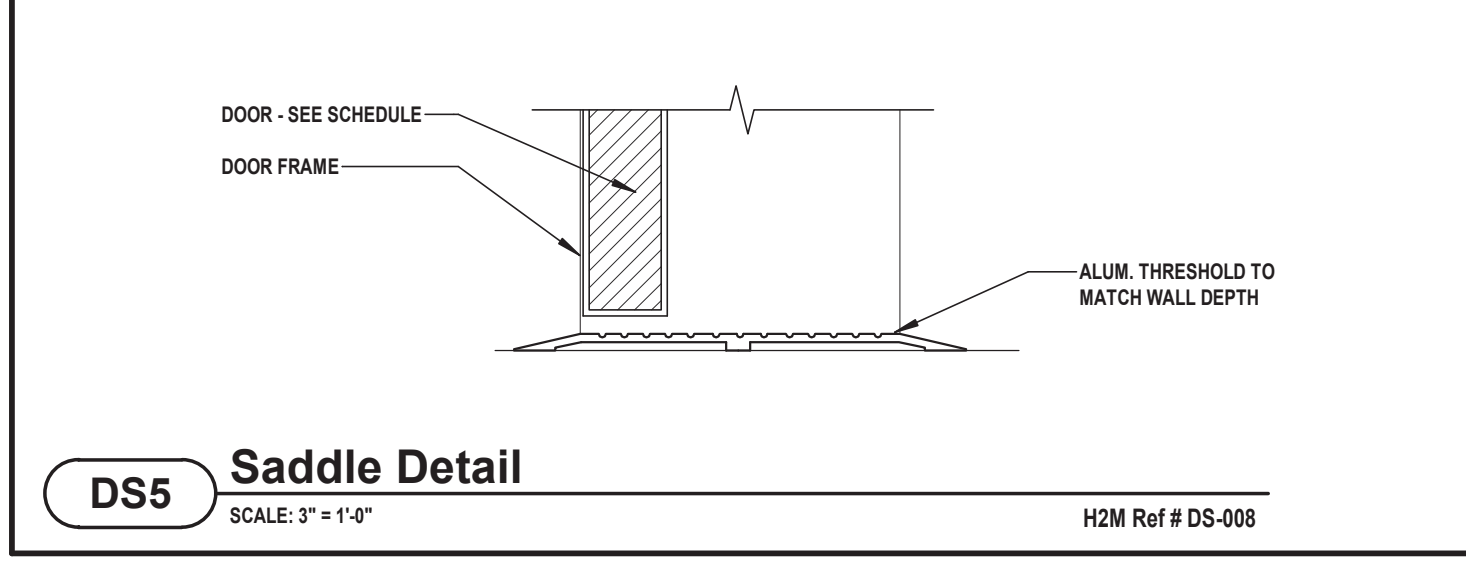

DS5 Saddle Detail
SCALE: 3" = 1'-0"
H2M Ref # DS-006

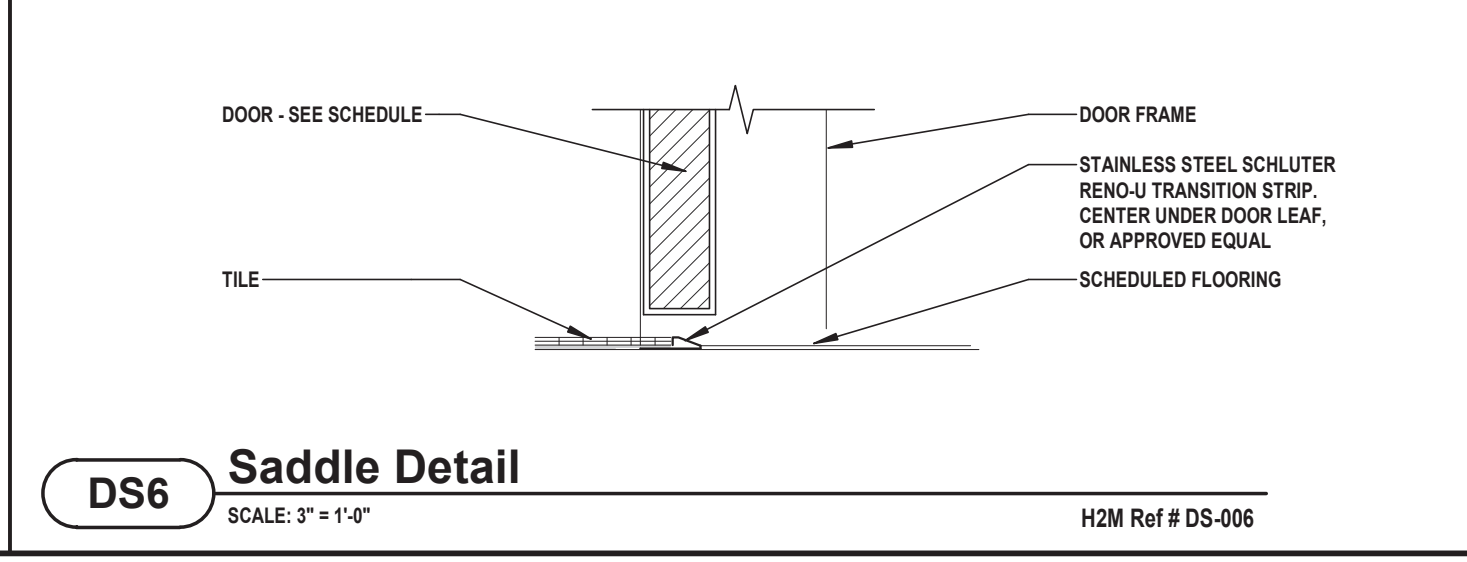

DS6 Saddle Detail
SCALE: 3" = 1'-0"
H2M Ref # DS-006

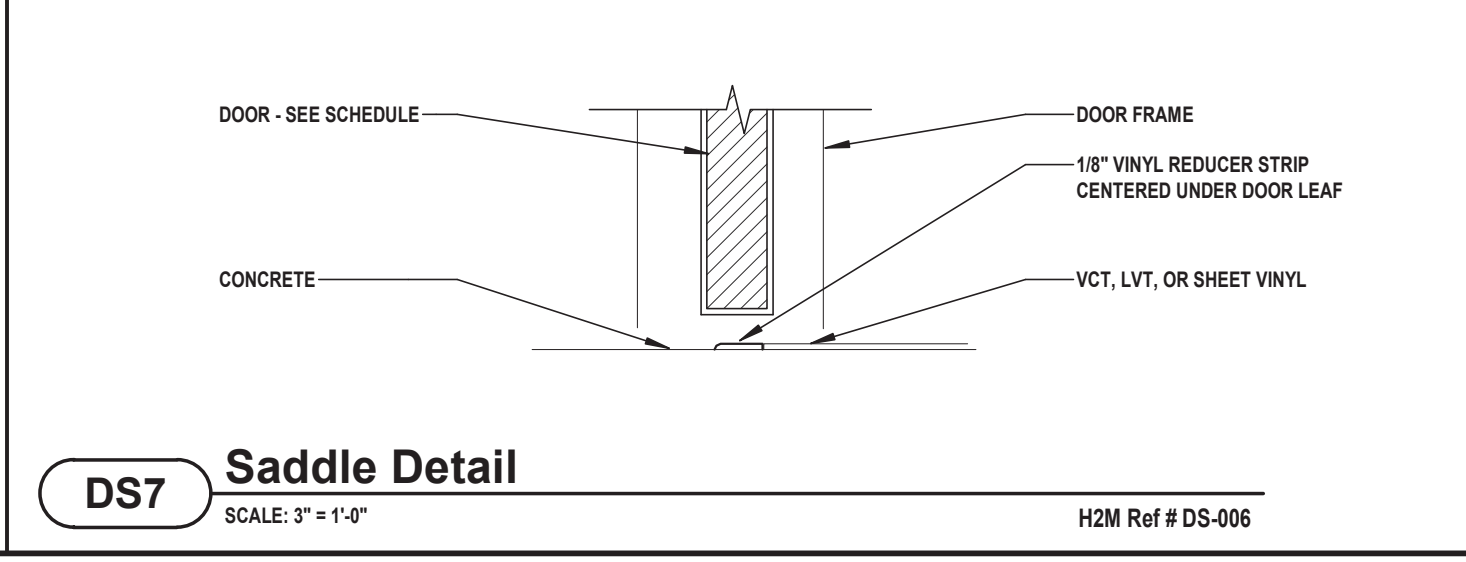

DS7 Saddle Detail
SCALE: 3" = 1'-0"
H2M Ref # DS-006



H2M

architects
+
engineers

538 Broad Hollow Road, 4th Floor East
Melville, NY 11747
631.756.8000 • www.h2m.com
NY Architecture & Landscape Architecture: No Certificate Required
NY Engineering Certificate of Authorization No.: 0018178

CONSULTANTS:

MARK	DATE	DESCRIPTION

REGISTERED ARCHITECT
PATRICK O. STONE
STATE OF NEW YORK
029654

Patrick O. Stone
PATRICK O. STONE, R.A.
NY PROFESSIONAL ARCHITECT LIC. NO. 029654
10/31/2025
Exp. Date

DESIGNED BY: DBS/RLG
PROJECT No: TRFD 2302

DRAWN BY: ANK
DATE: FEBRUARY 2025

CHECKED BY: DBS
SCALE: AS SHOWN

REVIEWED BY: POS

CLIENT
**THIELLS
ROSEVILLE FIRE
DISTRICT**

NEW 26-100 FIRE
HEADQUARTERS


65 W RAMAPO ROAD
GARNERVILLE, NY 10923

CONTRACT
**CONTRACT G
GENERAL CONSTRUCTION**


STATUS
FINAL BID DOCUMENT

SHEET TITLE
DOOR DETAILS


DRAWING No.
A 621.00

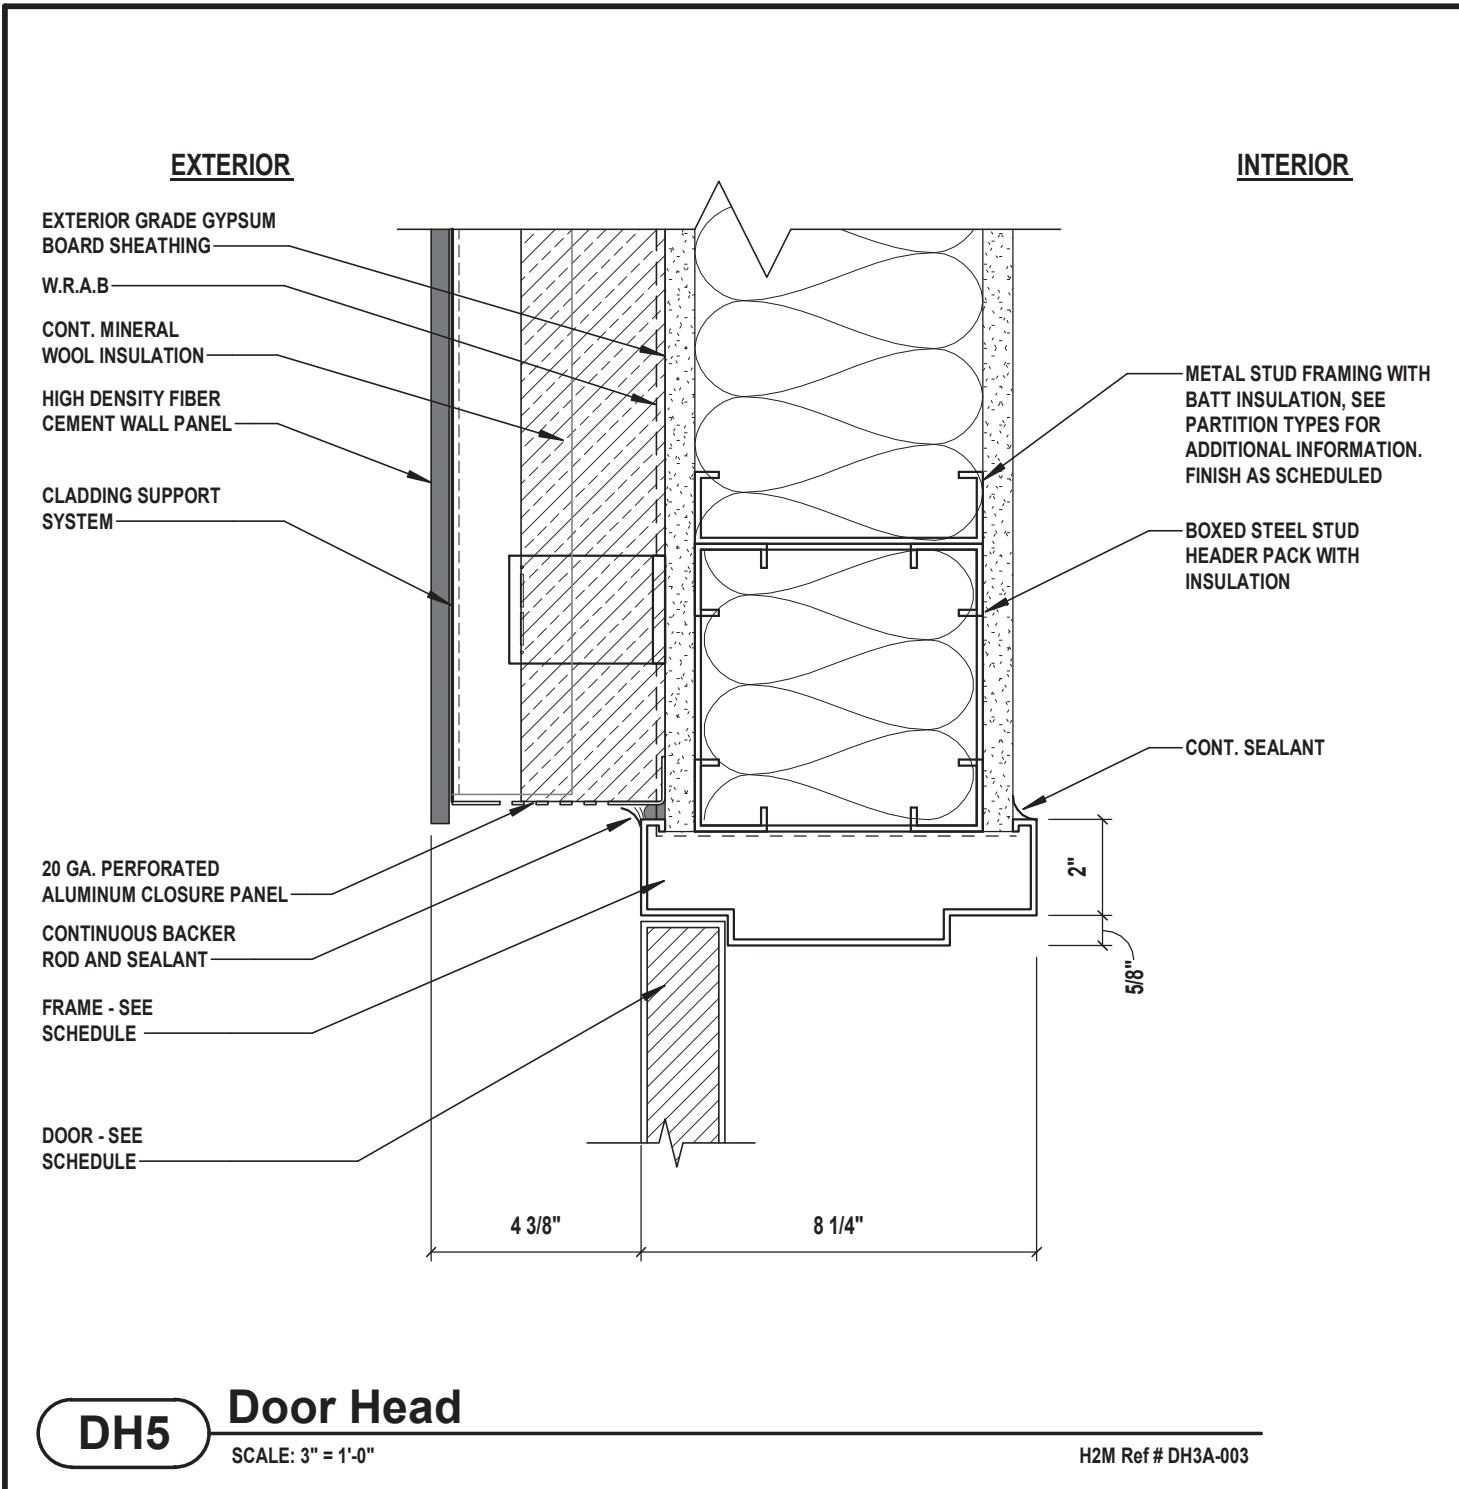


DH5 Door Head
SCALE: 3" = 1'-0" H2M Ref # DH3A-003

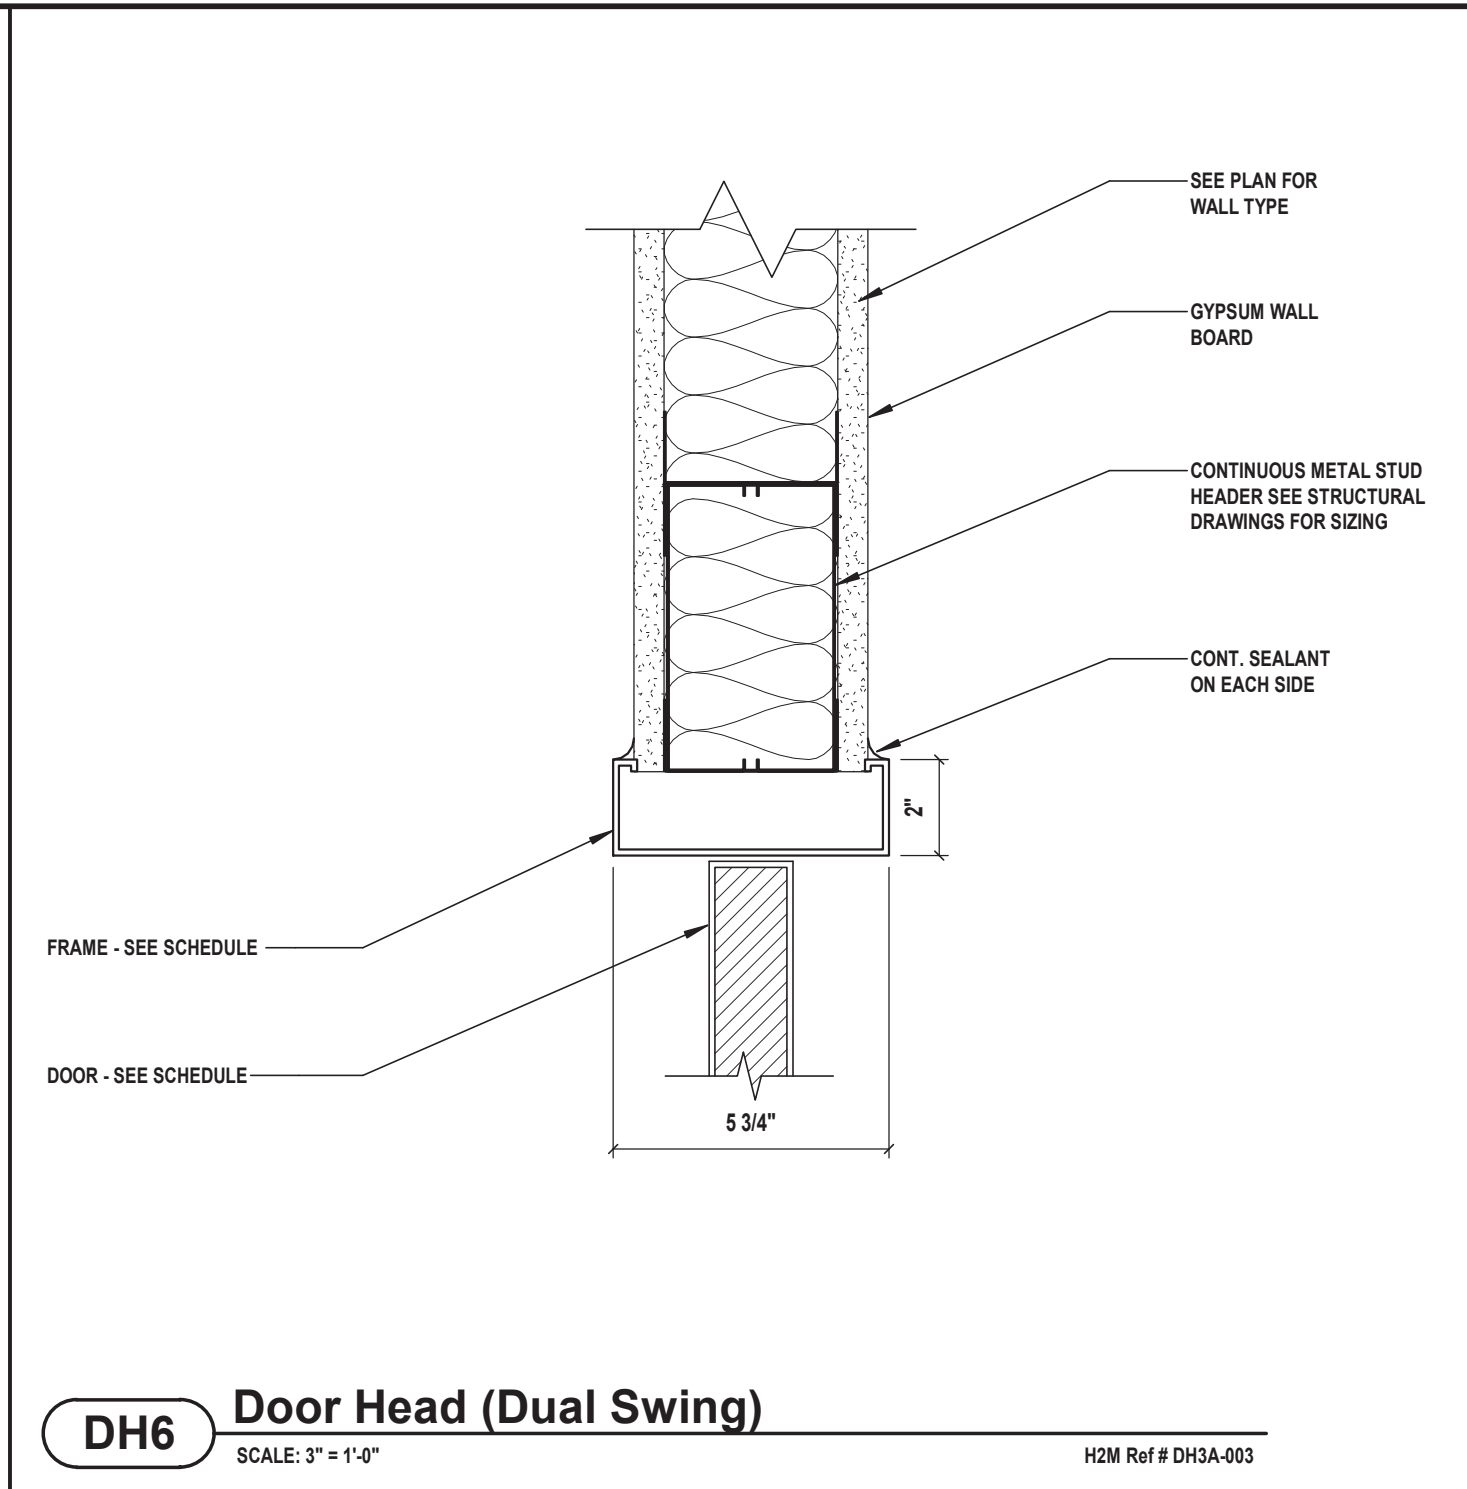


DH6 Door Head (Dual Swing)
SCALE: 3" = 1'-0" H2M Ref # DH3A-003

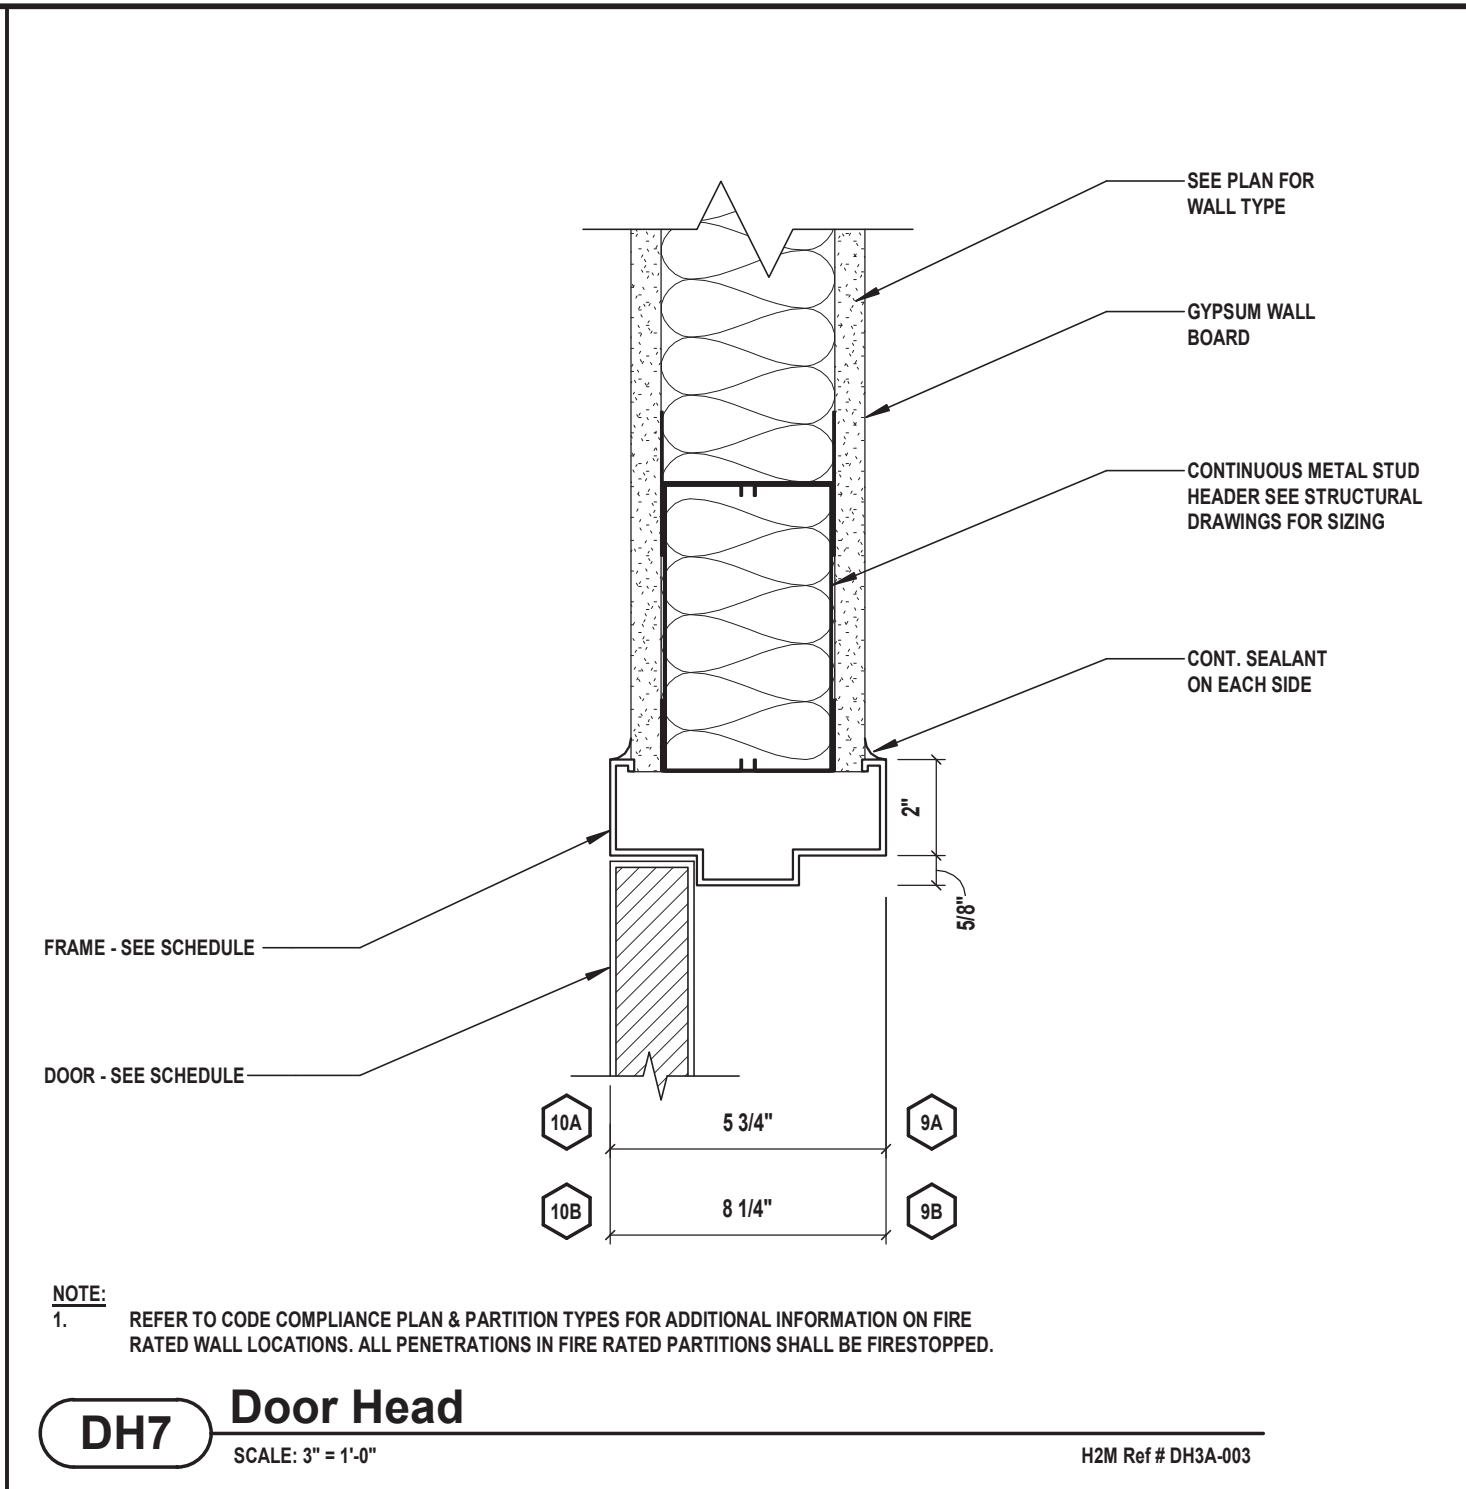


DH7 Door Head
SCALE: 3" = 1'-0" H2M Ref # DH3A-003

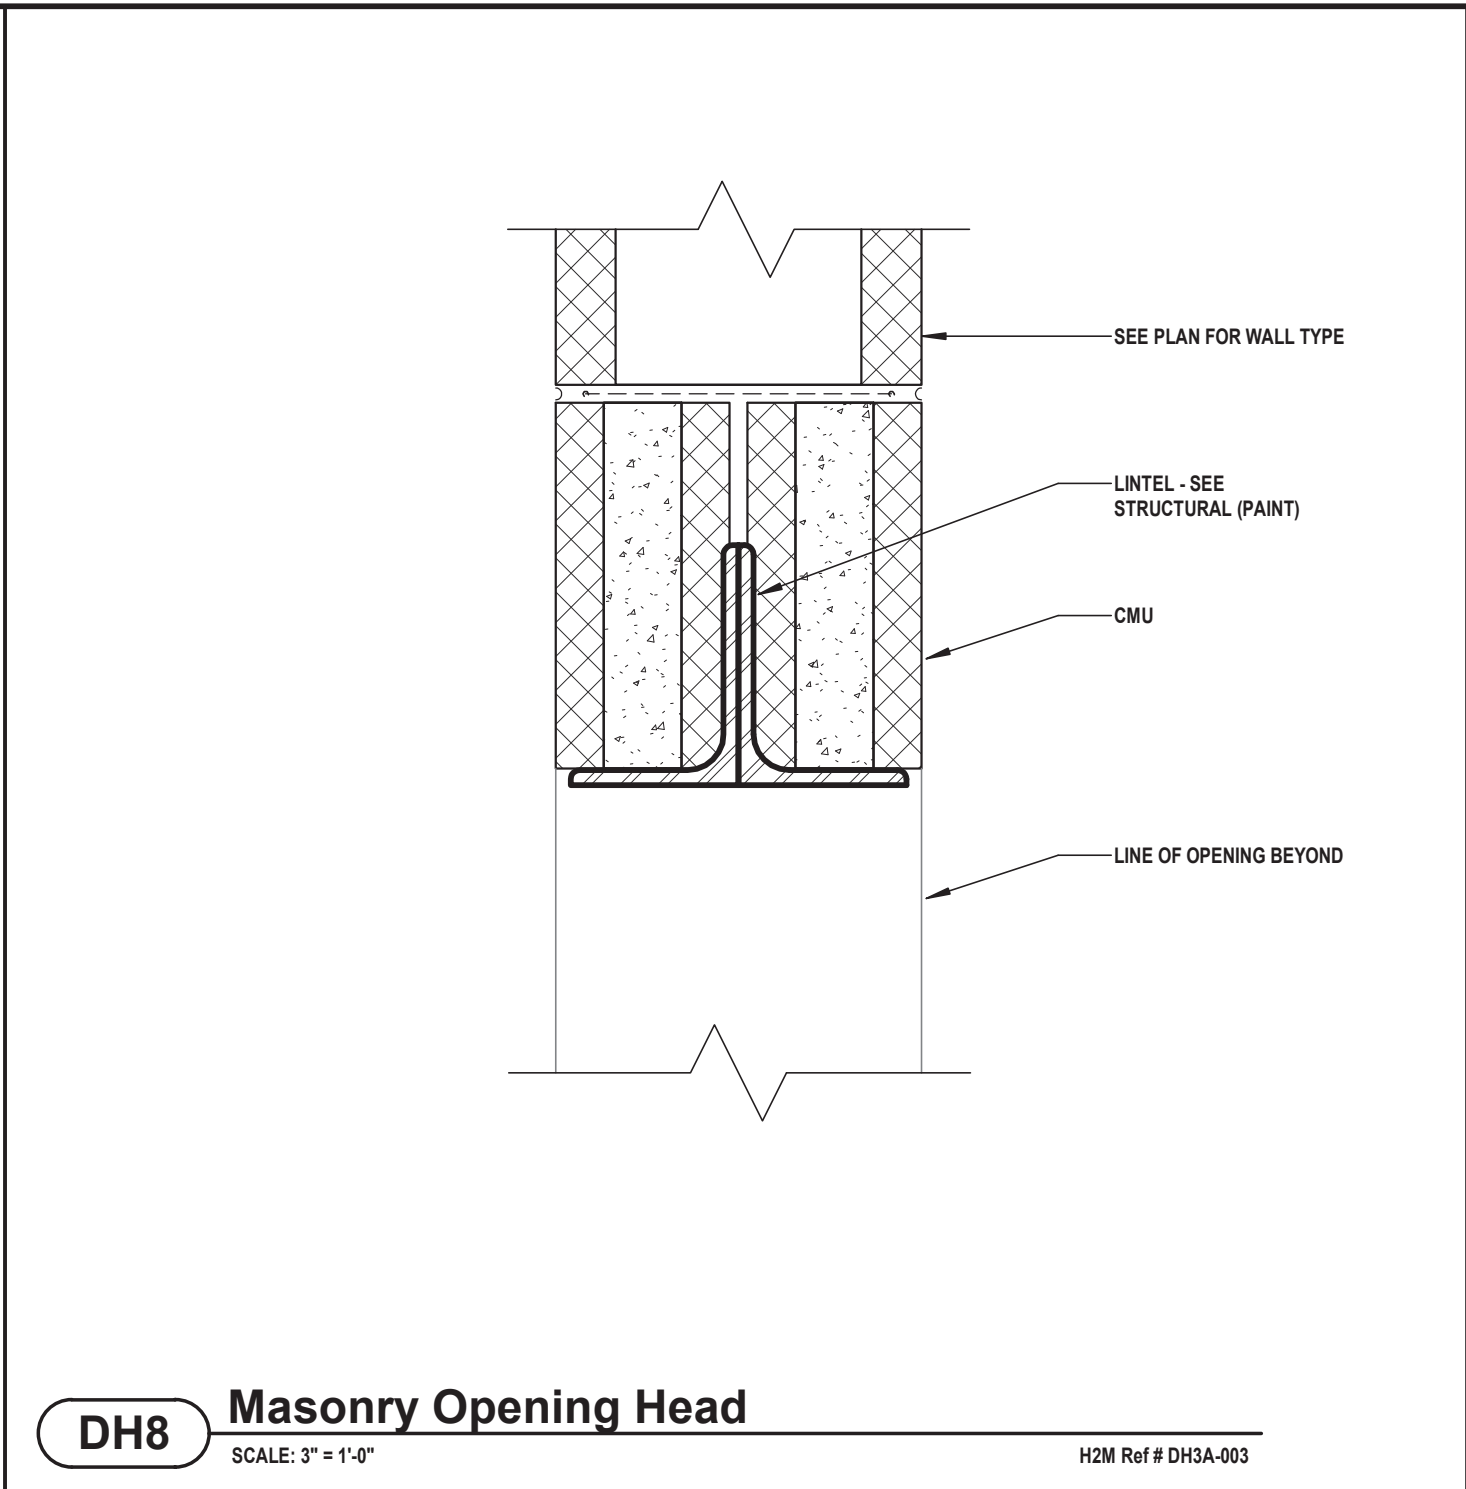


DH8 Masonry Opening Head
SCALE: 3" = 1'-0" H2M Ref # DH3A-003

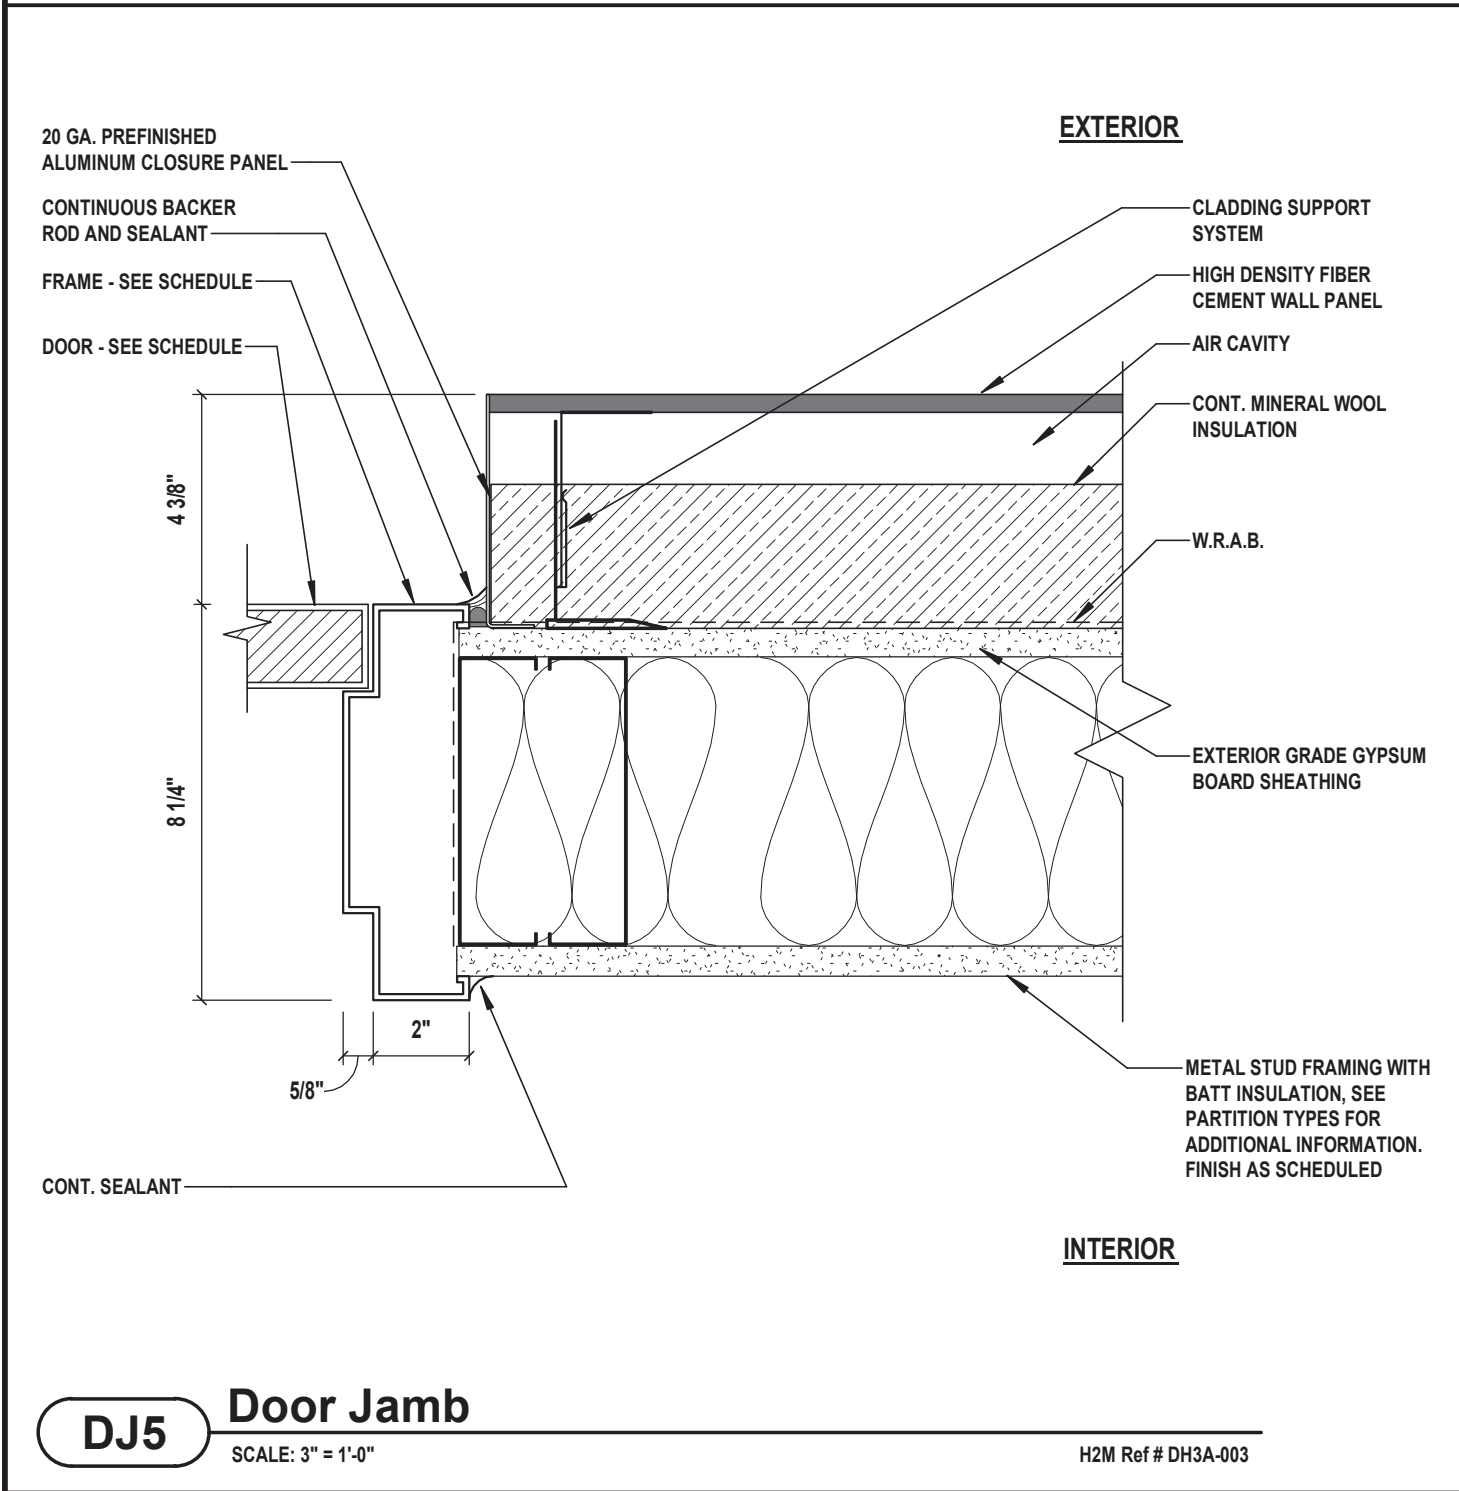


DJ5 Door Jamb
SCALE: 3" = 1'-0" H2M Ref # DH3A-003

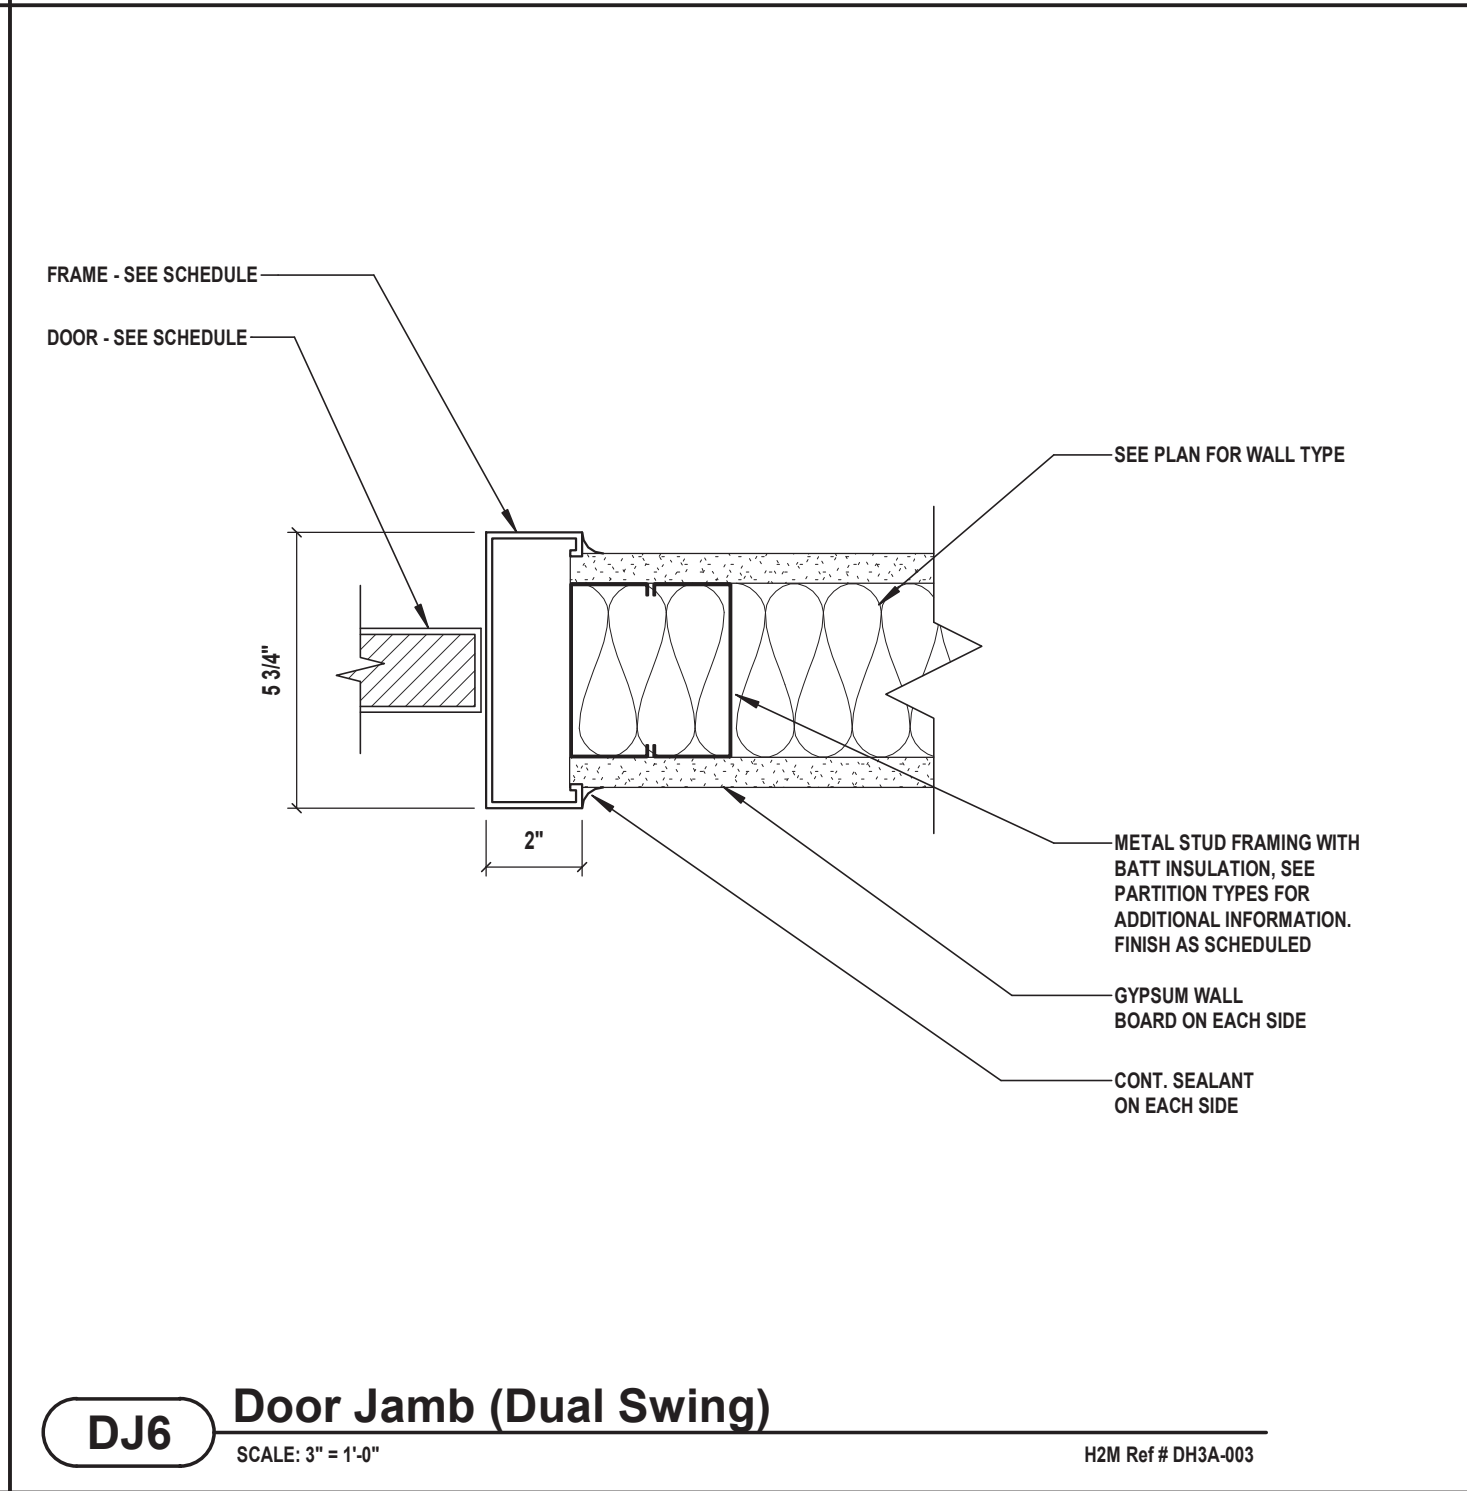

DJ6 Door Jamb (Dual Swing)
SCALE: 3" = 1'-0" H2M Ref # DH3A-003

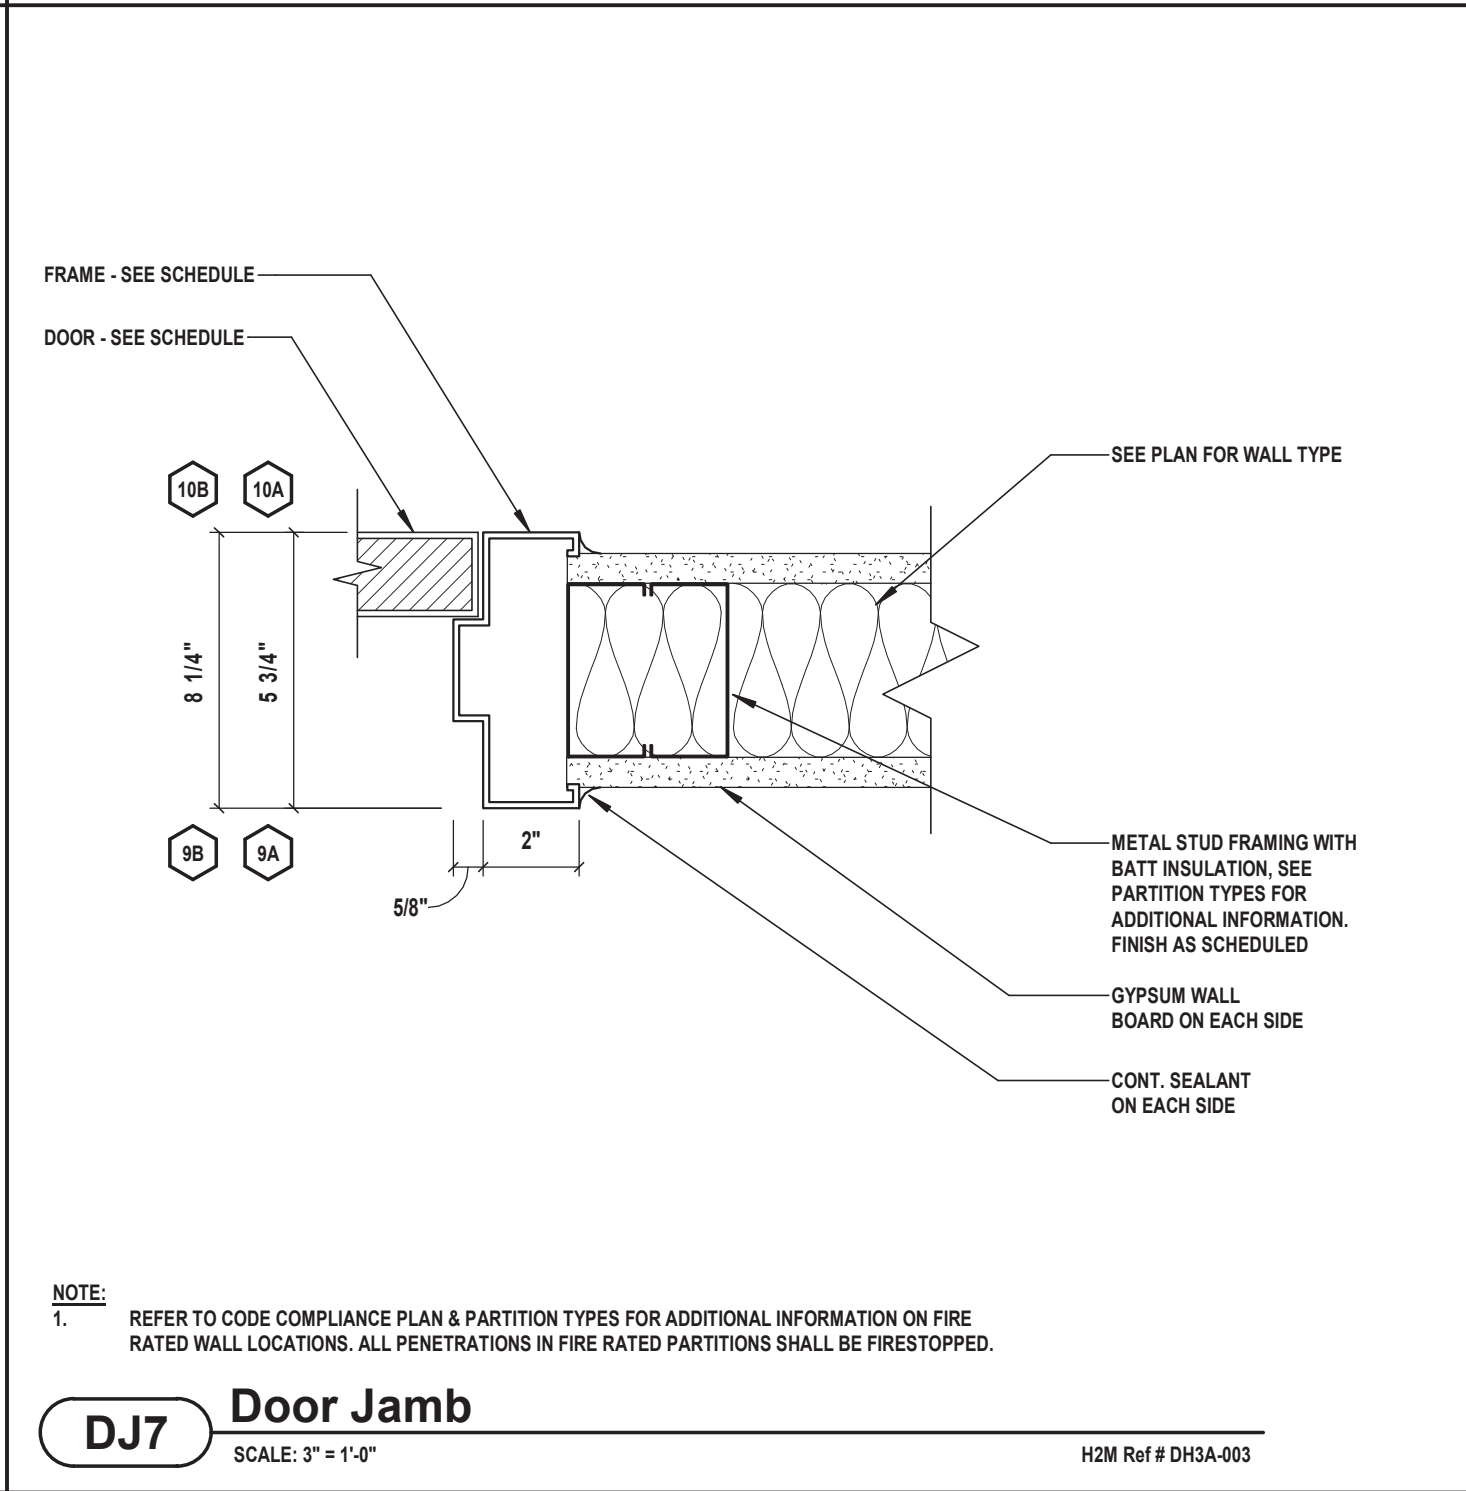

DJ7 Door Jamb
SCALE: 3" = 1'-0" H2M Ref # DH3A-003

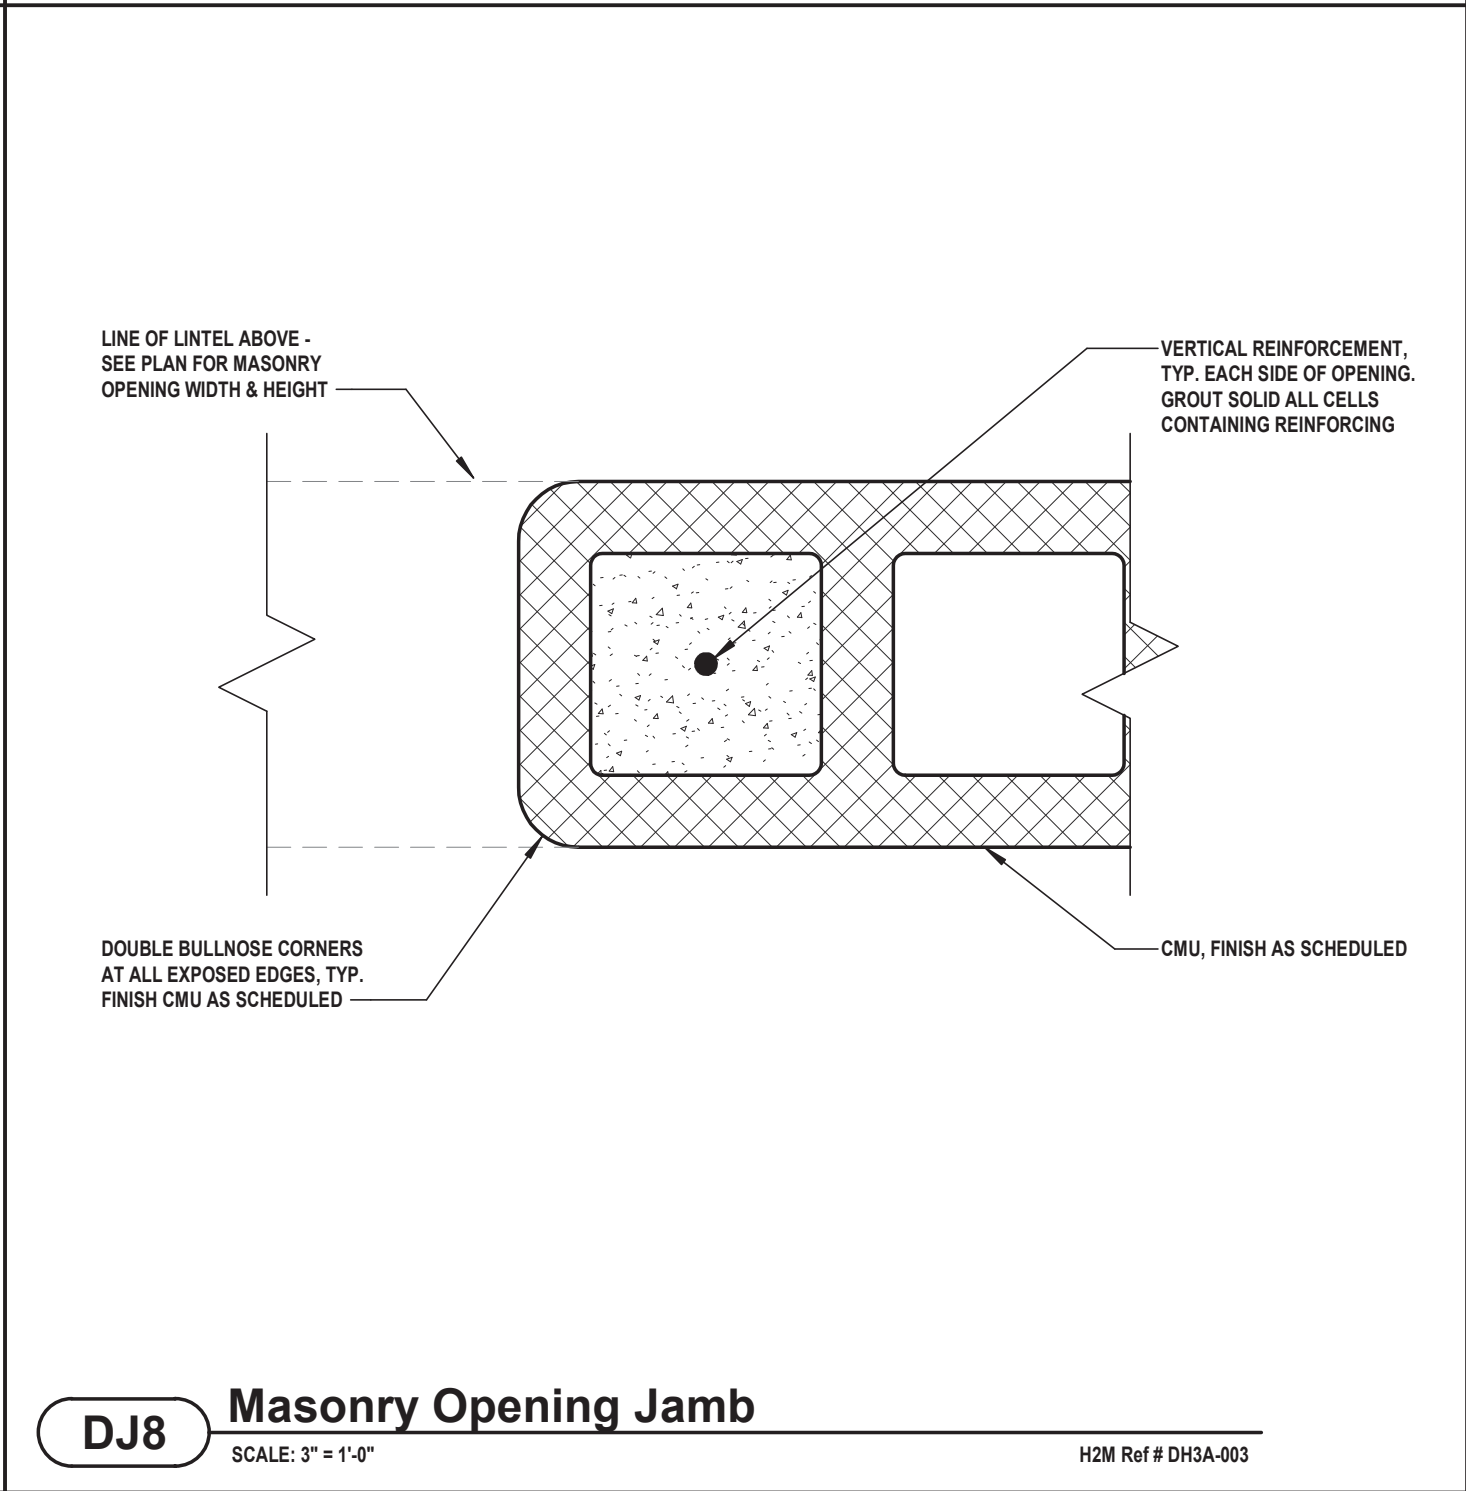

DJ8 Masonry Opening Jamb
SCALE: 3" = 1'-0" H2M Ref # DH3A-003

H2M architects + engineers

538 Broad Hollow Road, 4th Floor East
Melville, NY 11747
631.756.8000 • www.h2m.com
NY Architecture & Landscape Architecture: No Certificate Required
NY Engineering Certificate of Authorization No.: 0018178

CONSULTANTS:		

MARK	DATE	DESCRIPTION



PATRICK O. STONE, R.A.
NY PROFESSIONAL ARCHITECT LIC. NO. 029654
Exp. Date: 10/31/2025

*IN ACCORDANCE WITH ARTICLE 145, SECTION 1209 OF THE NYS EDUCATION LAW, ALTERNATION OF THIS DOCUMENT EXCEPT BY A LICENSED PROFESSIONAL IS ILLEGAL.

DESIGNED BY:	DRAWN BY:	CHECKED BY:	REVIEWED BY:
DBS/RLG	ANK	DBS	POS
PROJECT No:	DATE:	SCALE:	AS SHOWN
TRFD 2302	FEBRUARY 2025		

CLIENT

**THIELLS
ROSEVILLE FIRE
DISTRICT**

NEW 26-100 FIRE
HEADQUARTERS



65 W RAMAPO ROAD
GARNERVILLE, NY 10923

CONTRACT
**CONTRACT G
GENERAL CONSTRUCTION**

STATUS
FINAL BID DOCUMENT

SHEET TITLE
DOOR DETAILS

DRAWING No.
A 622.00

[illegible]



10/31/2025
Exp. Date
PATRICK O. STONE, R.A.
NY PROFESSIONAL ARCHITECT Lic. No. 009464

"IN ACCORDANCE WITH ARTICLE 145, SECTION 7209 OF THE MYS EDUCATION LAW, ALTERATION OF THIS DOCUMENT EXCEPT BY A LICENSED PROFESSIONAL IS ILLEGAL"			
DESIGNED BY: DBS/RLG	DRAWN BY: ANK	CHECKED BY: DBS	REVIEWED BY: POS
PROJECT No: TRFD 2302	DATE: FEBRUARY 2025	SCALE: AS SHOWN	

CLIENT _____

**THIELLS
ROSEVILLE FIRE
DISTRICT**

NEW 26-100 FIRE HEADQUARTERS



65 W RAMAPO ROAD
GARNERVILLE, NY 10923


CONTRACT

CONTRACT G
GENERAL CONSTRUCTION


STATUS	FINAL BID DOCUMENT
--------	--------------------

SHEET TITLE
DOOR DETAILS


DRAWING No. **A 623.00**

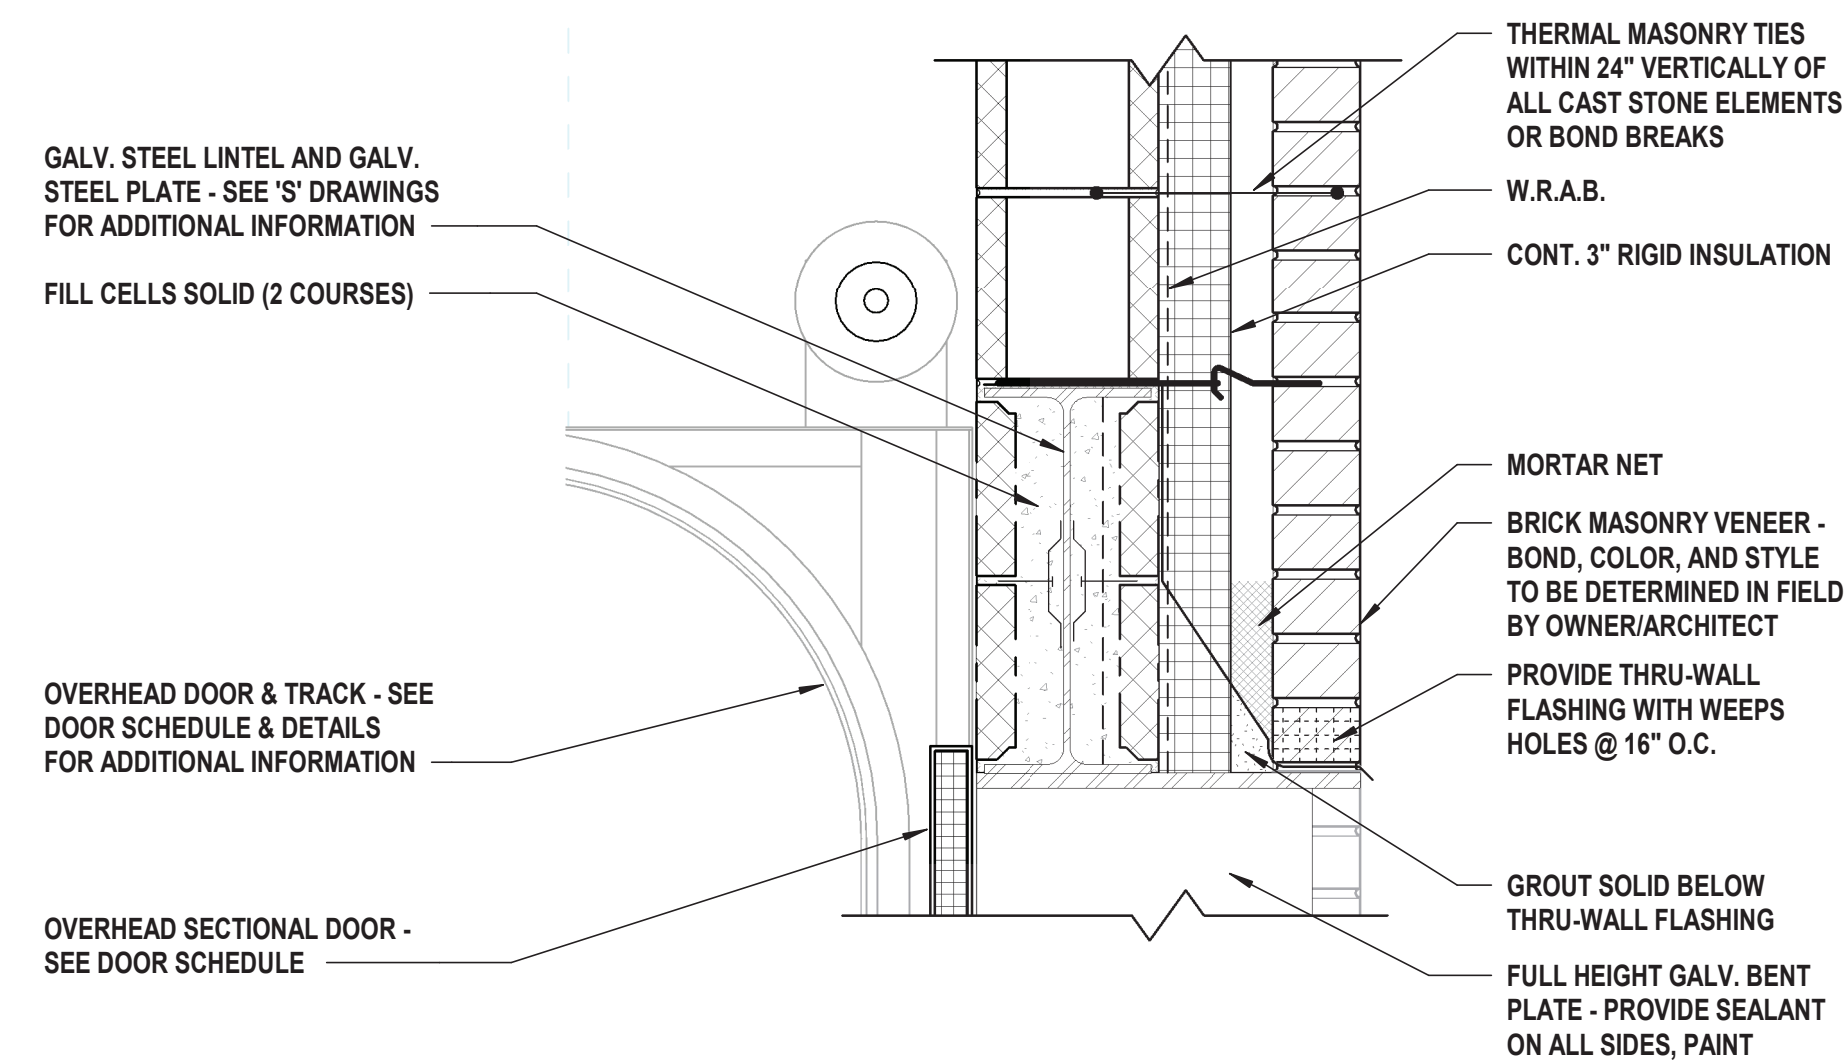


1 Overhead Door Head Detail (Base Bid)
SCALE: 1 1/2" = 1'-0"

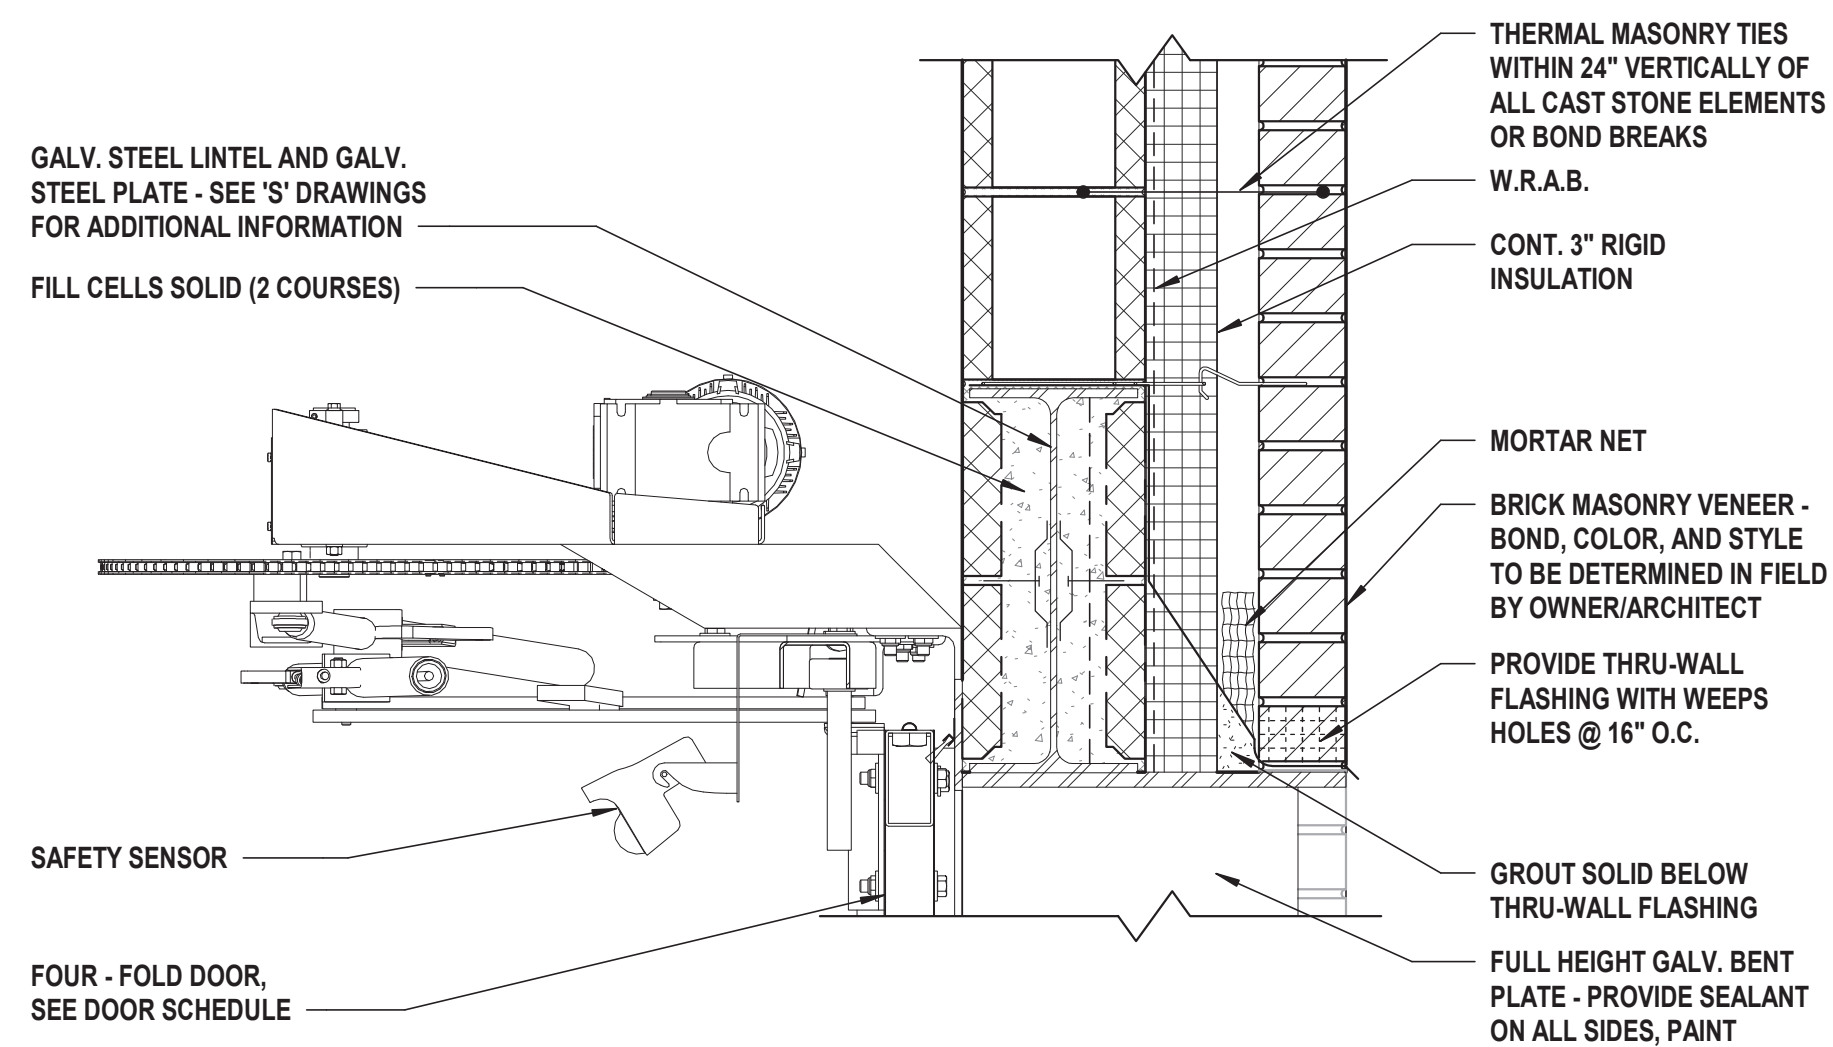


2 Fold Door Head Detail (Alternate G-01)
SCALE: 1 1/2" = 1'-0"

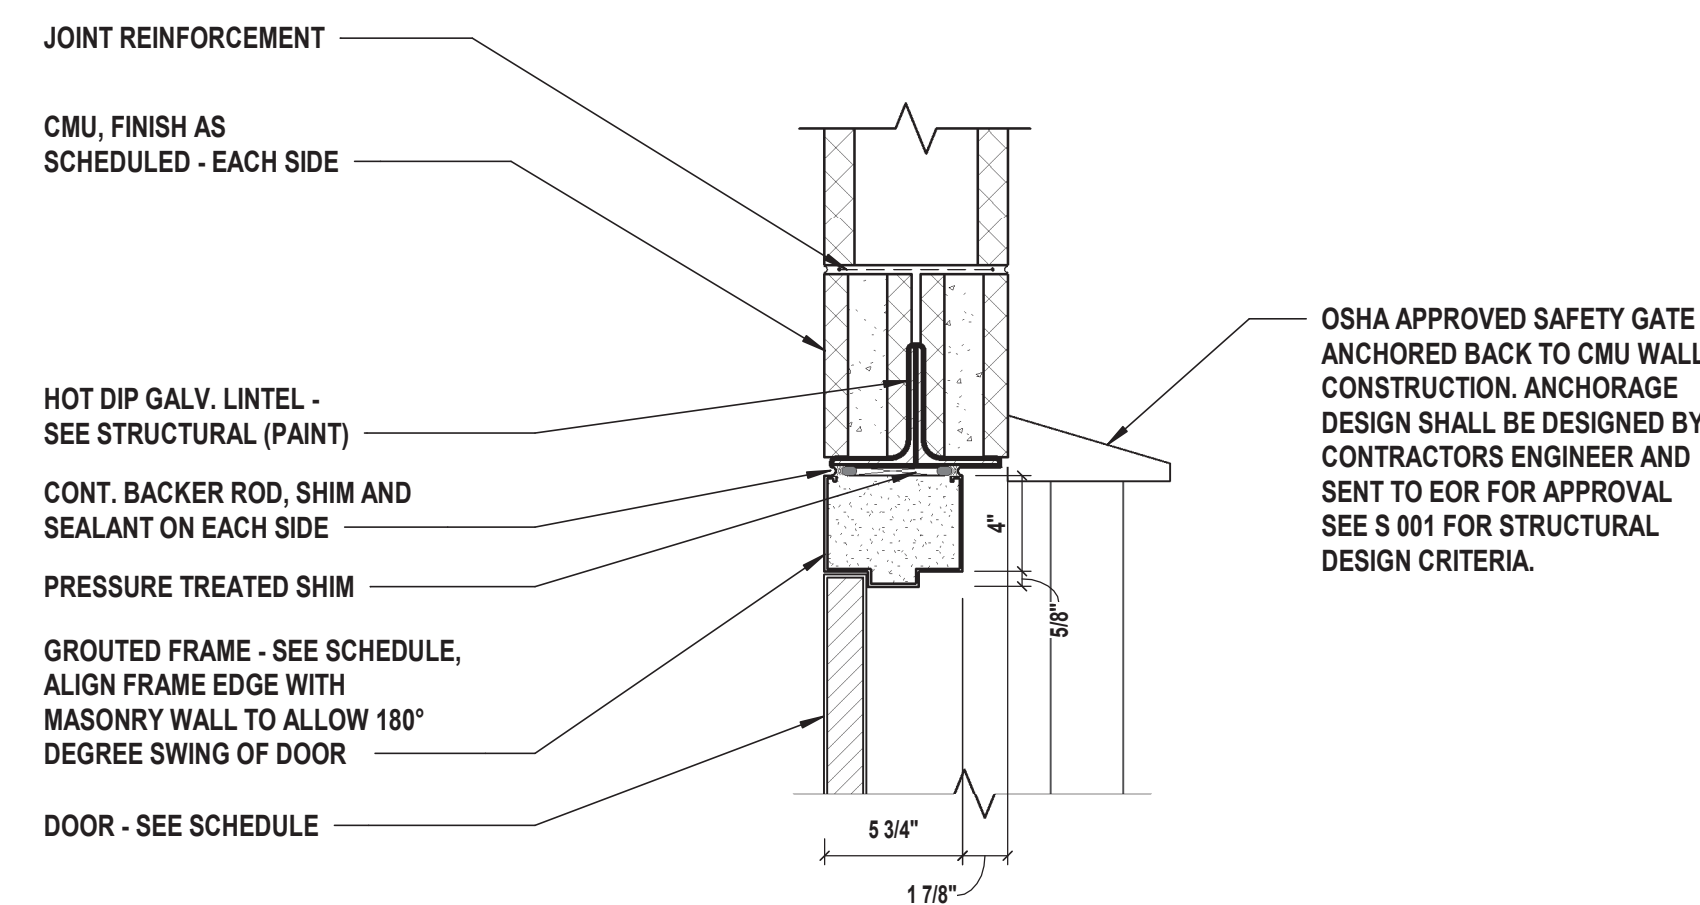


3 Mezzanine Door Gate Head Detail

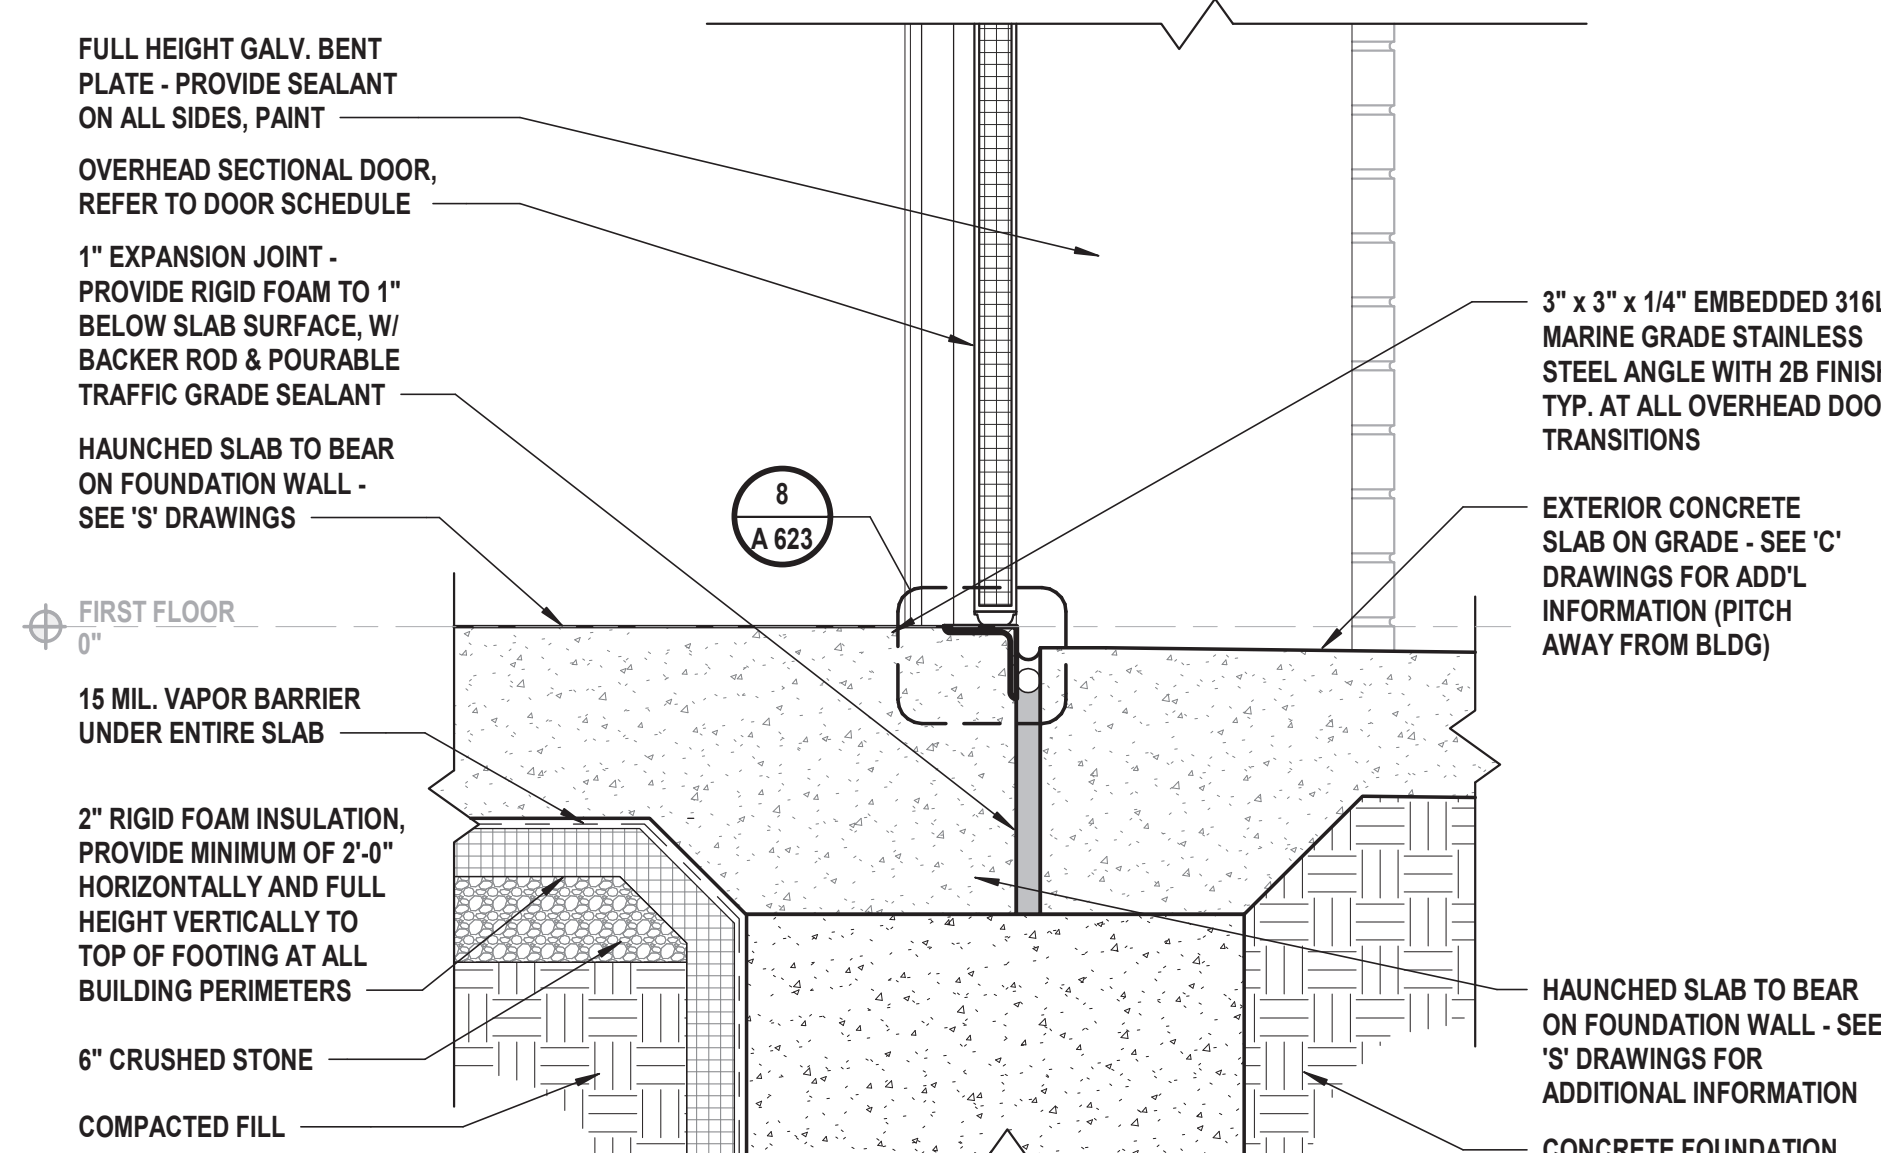


4 Overhead Door Saddle Detail (Base Bid)
SCALE: 1 1/2" = 1'-0"

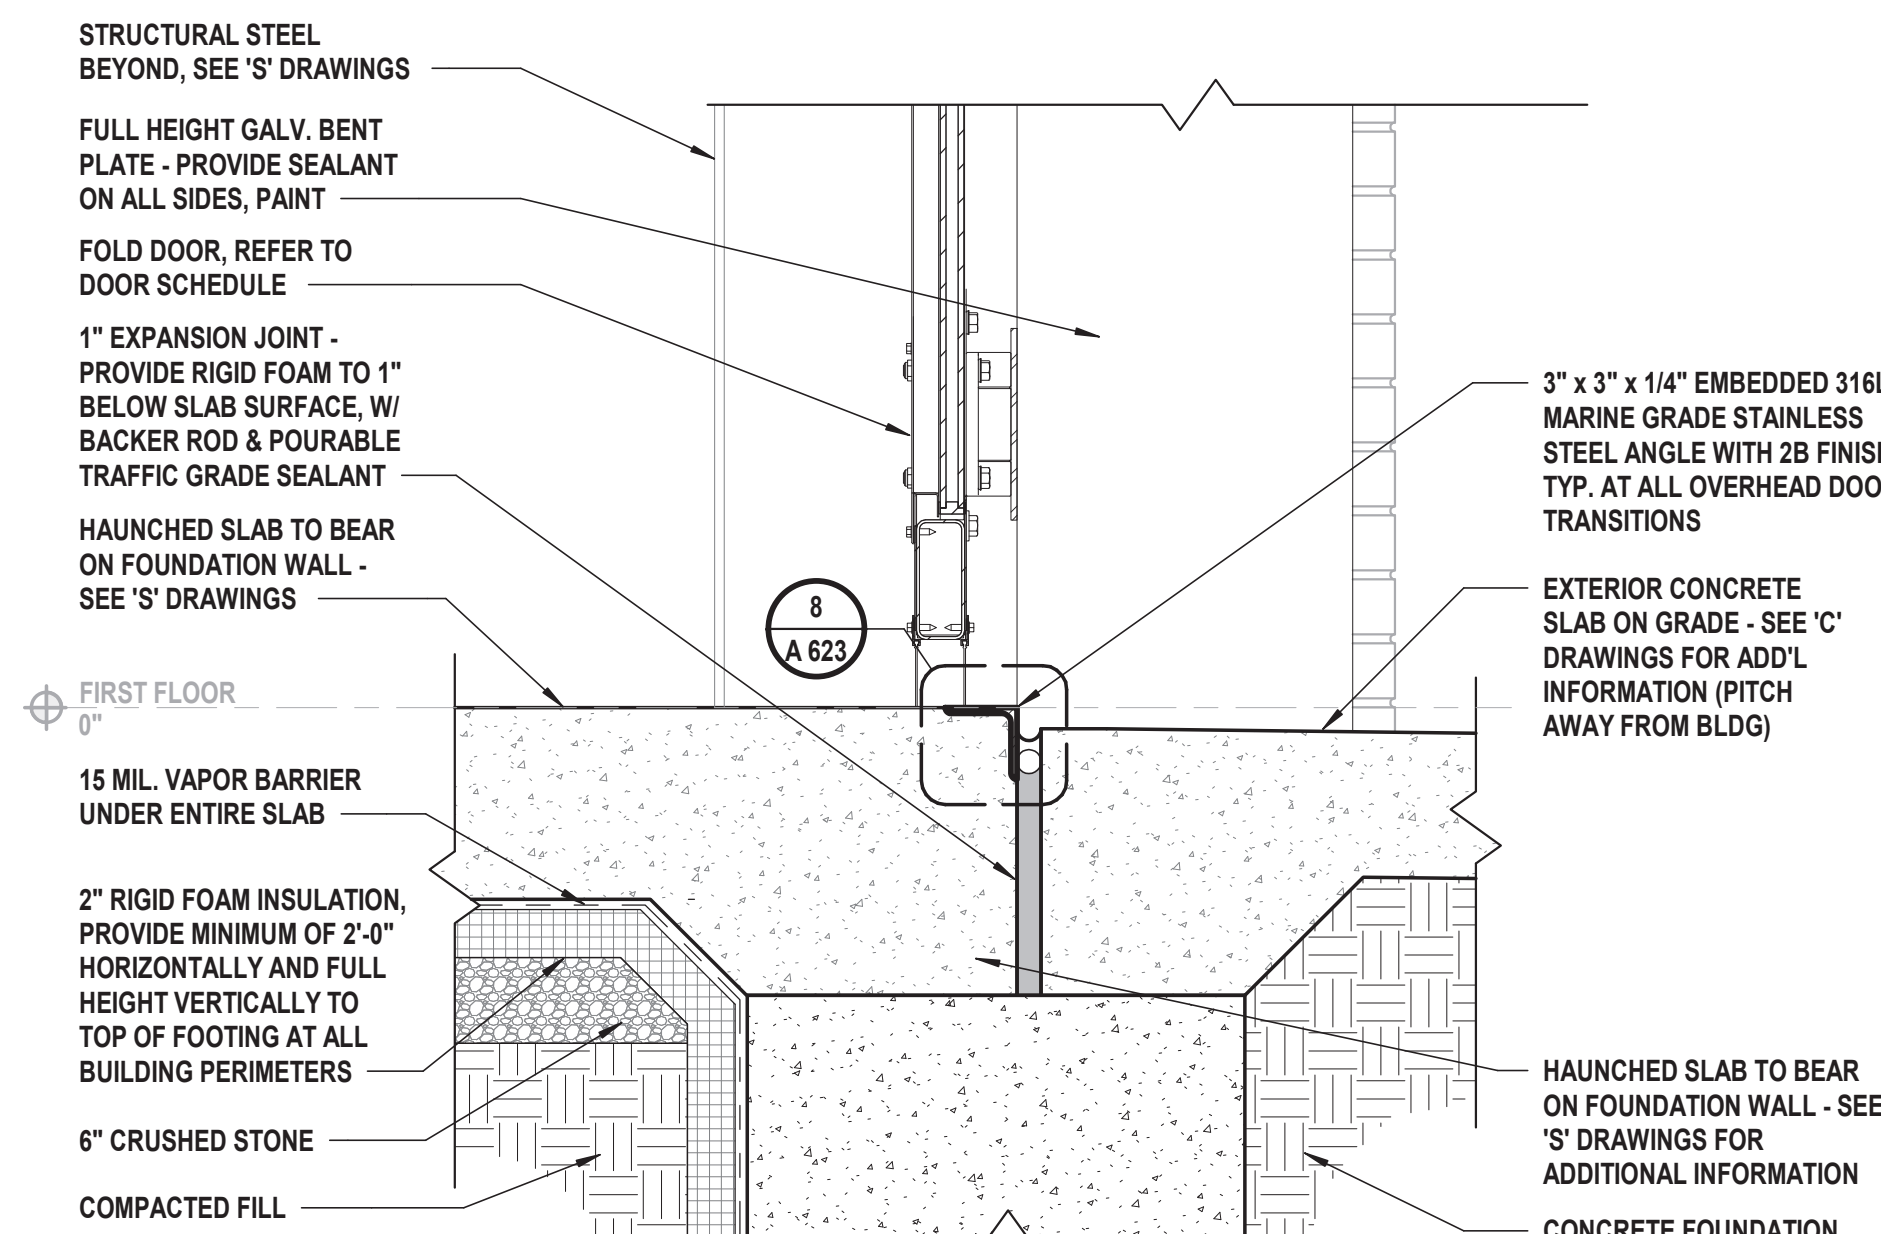


5 Fold Door Saddle Detail (Alternate G-01)
SCALE: 1 1/2" = 1'-0"

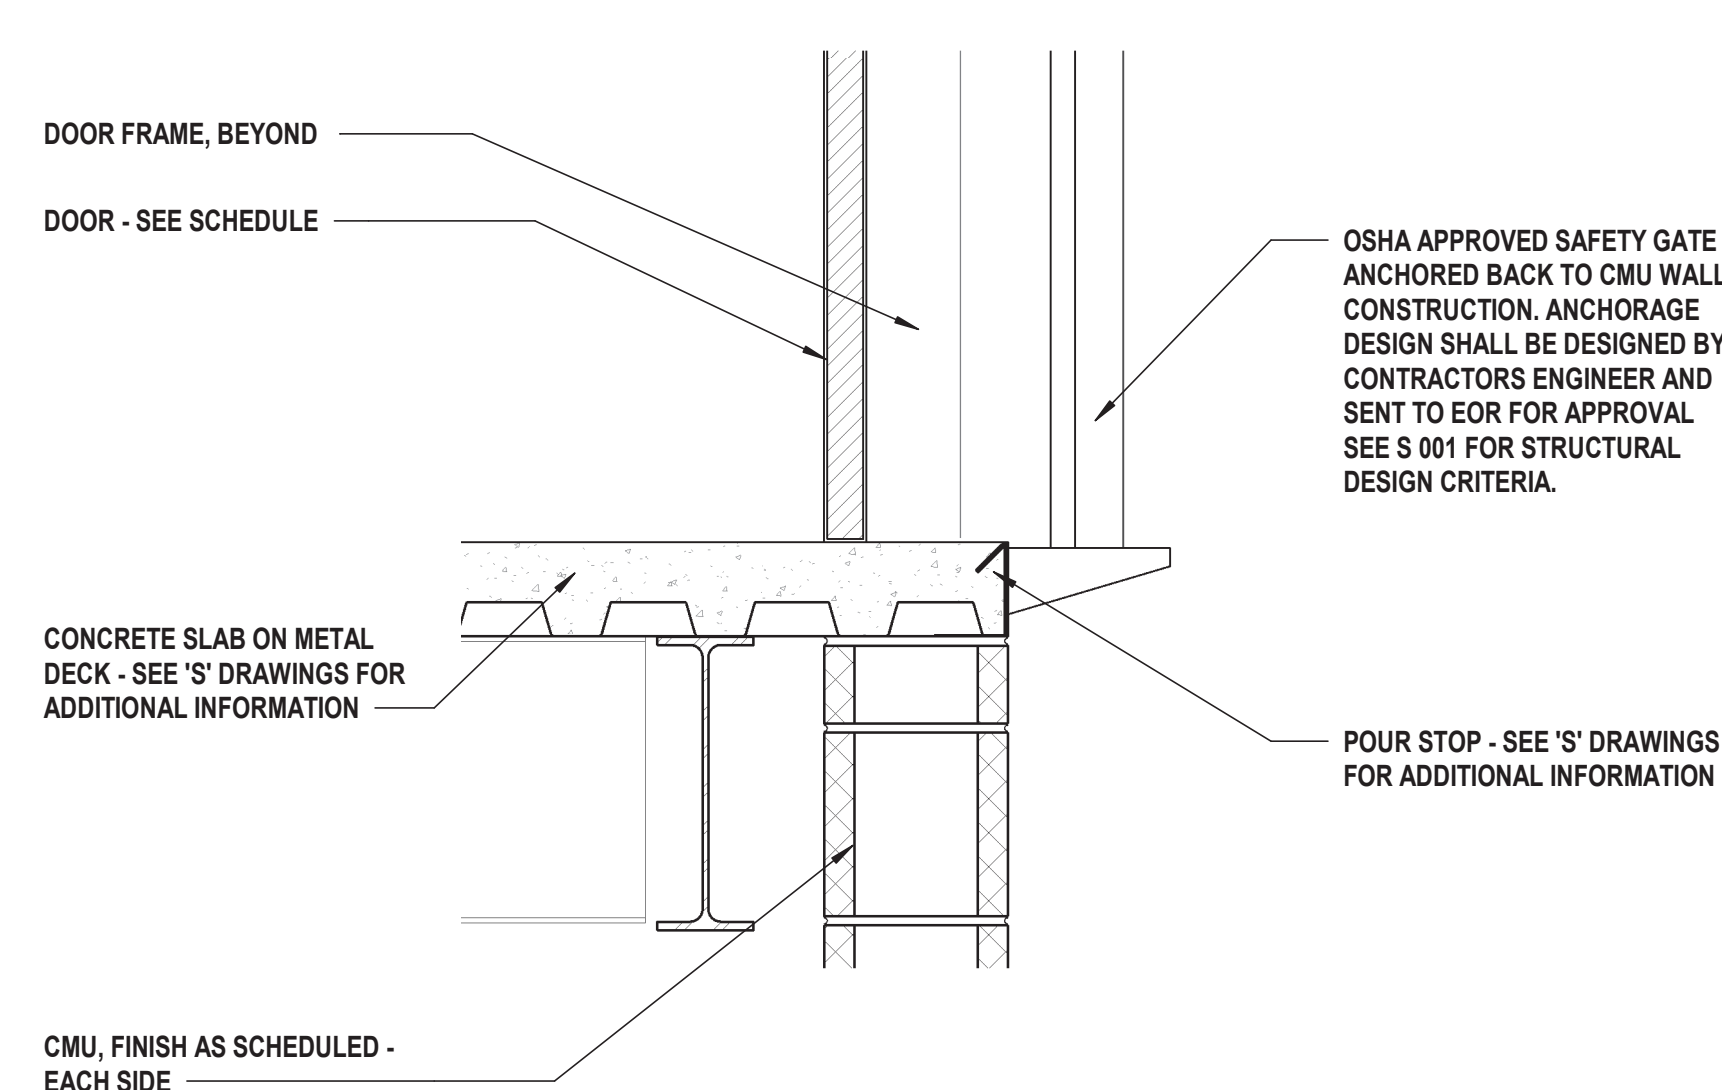


6 Mezzanine Door Gate Sill Detail

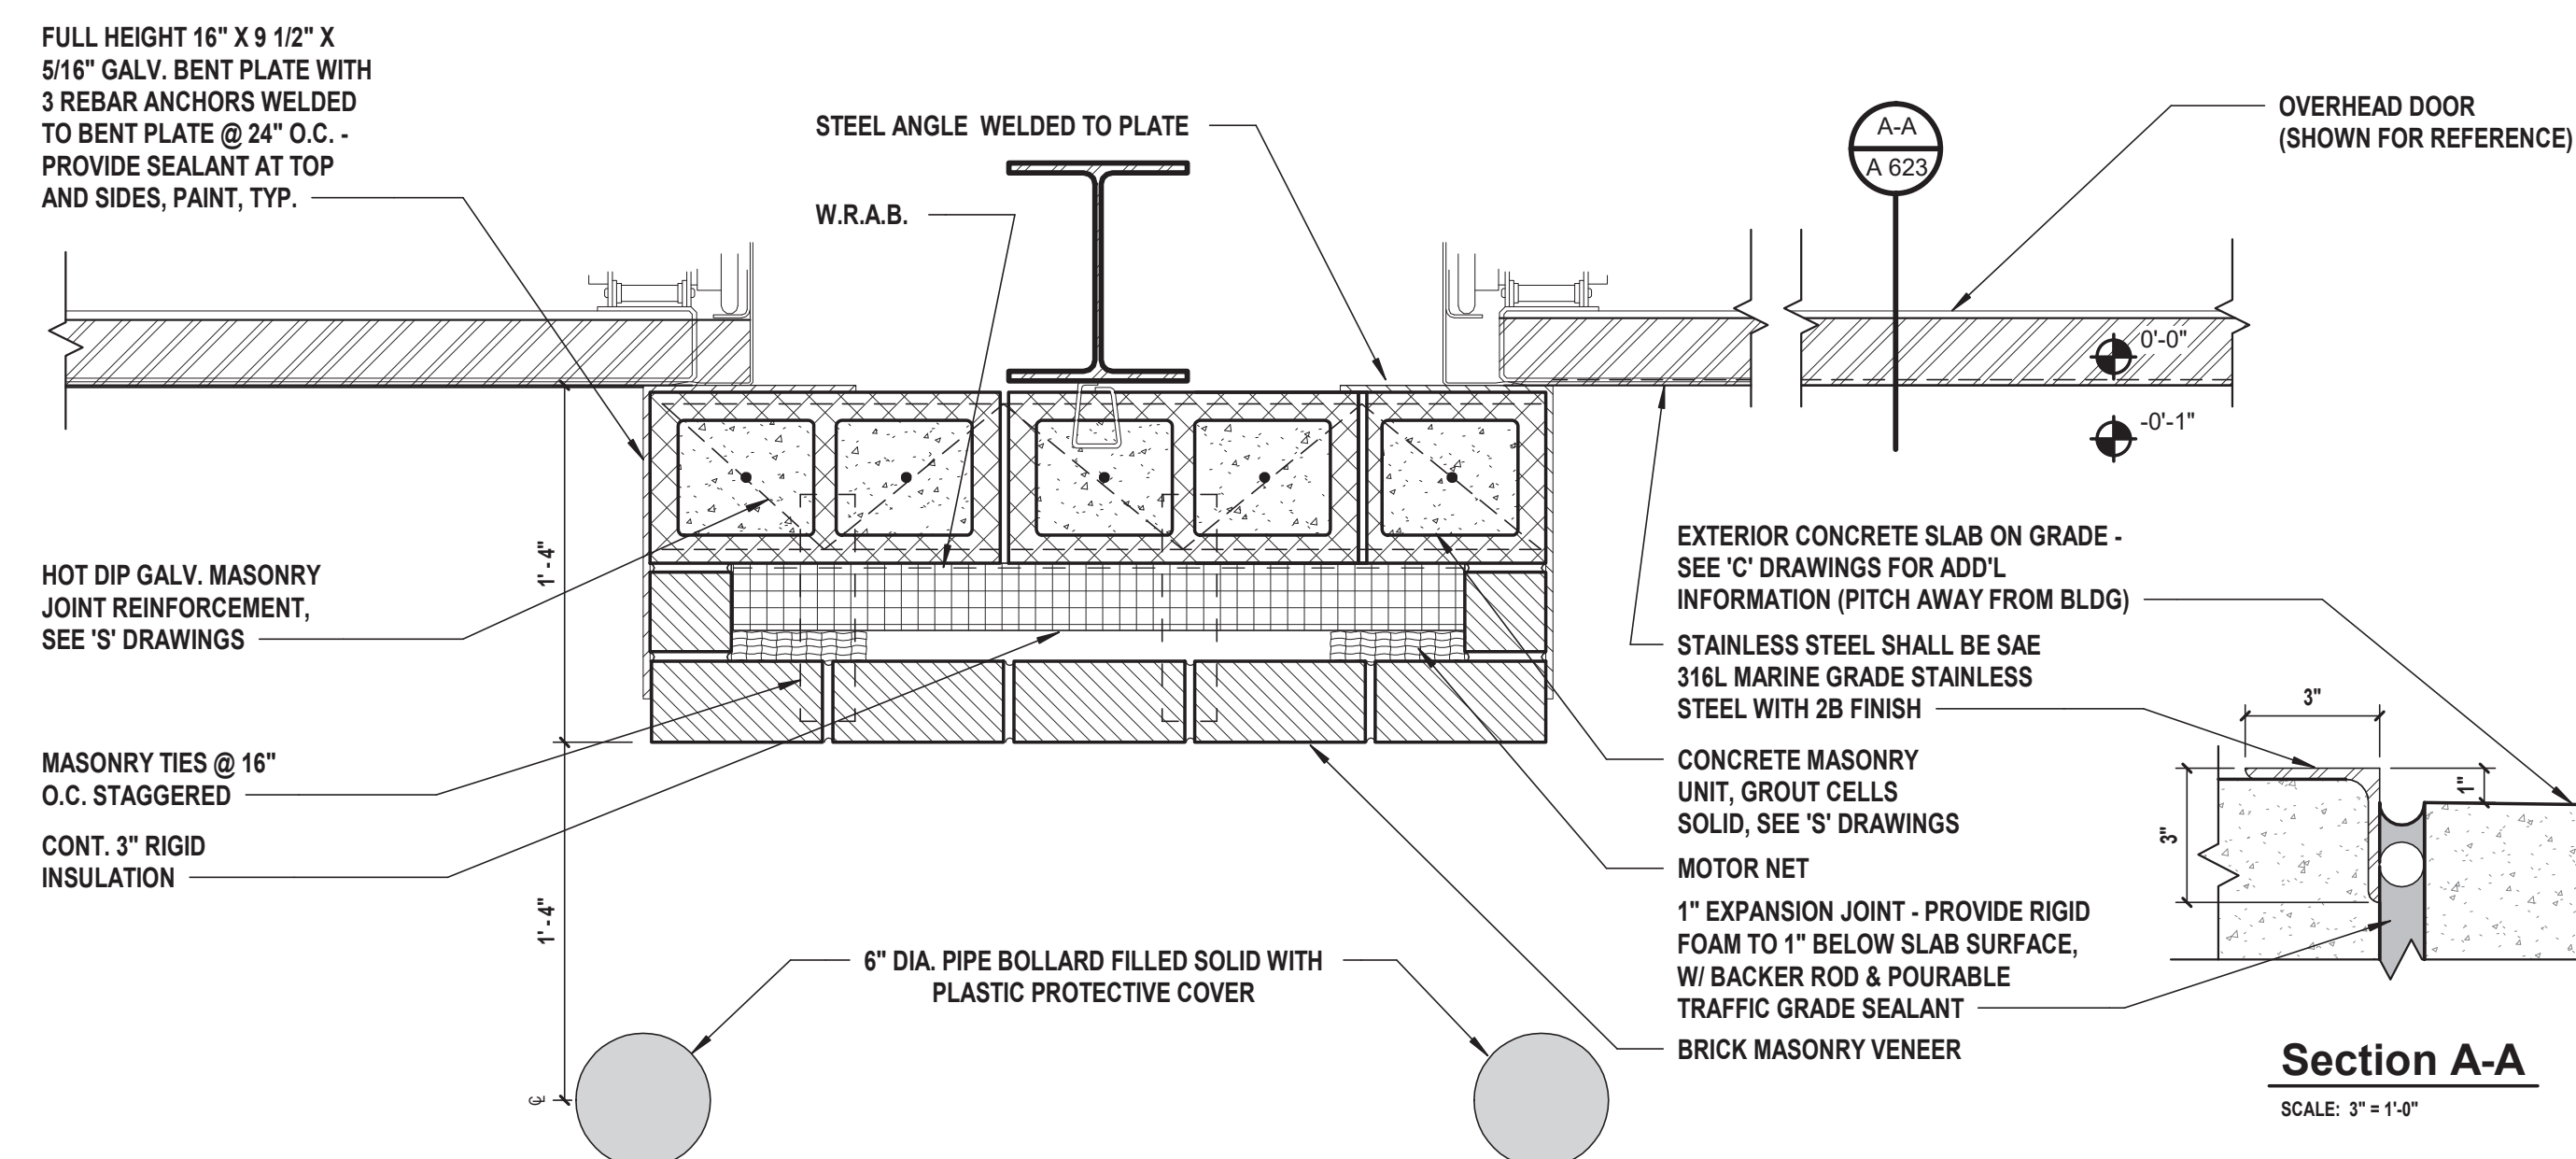

7 Overhead Door Jamb Detail (Base Bid)
SCALE: 1 1/2" = 1'-0"

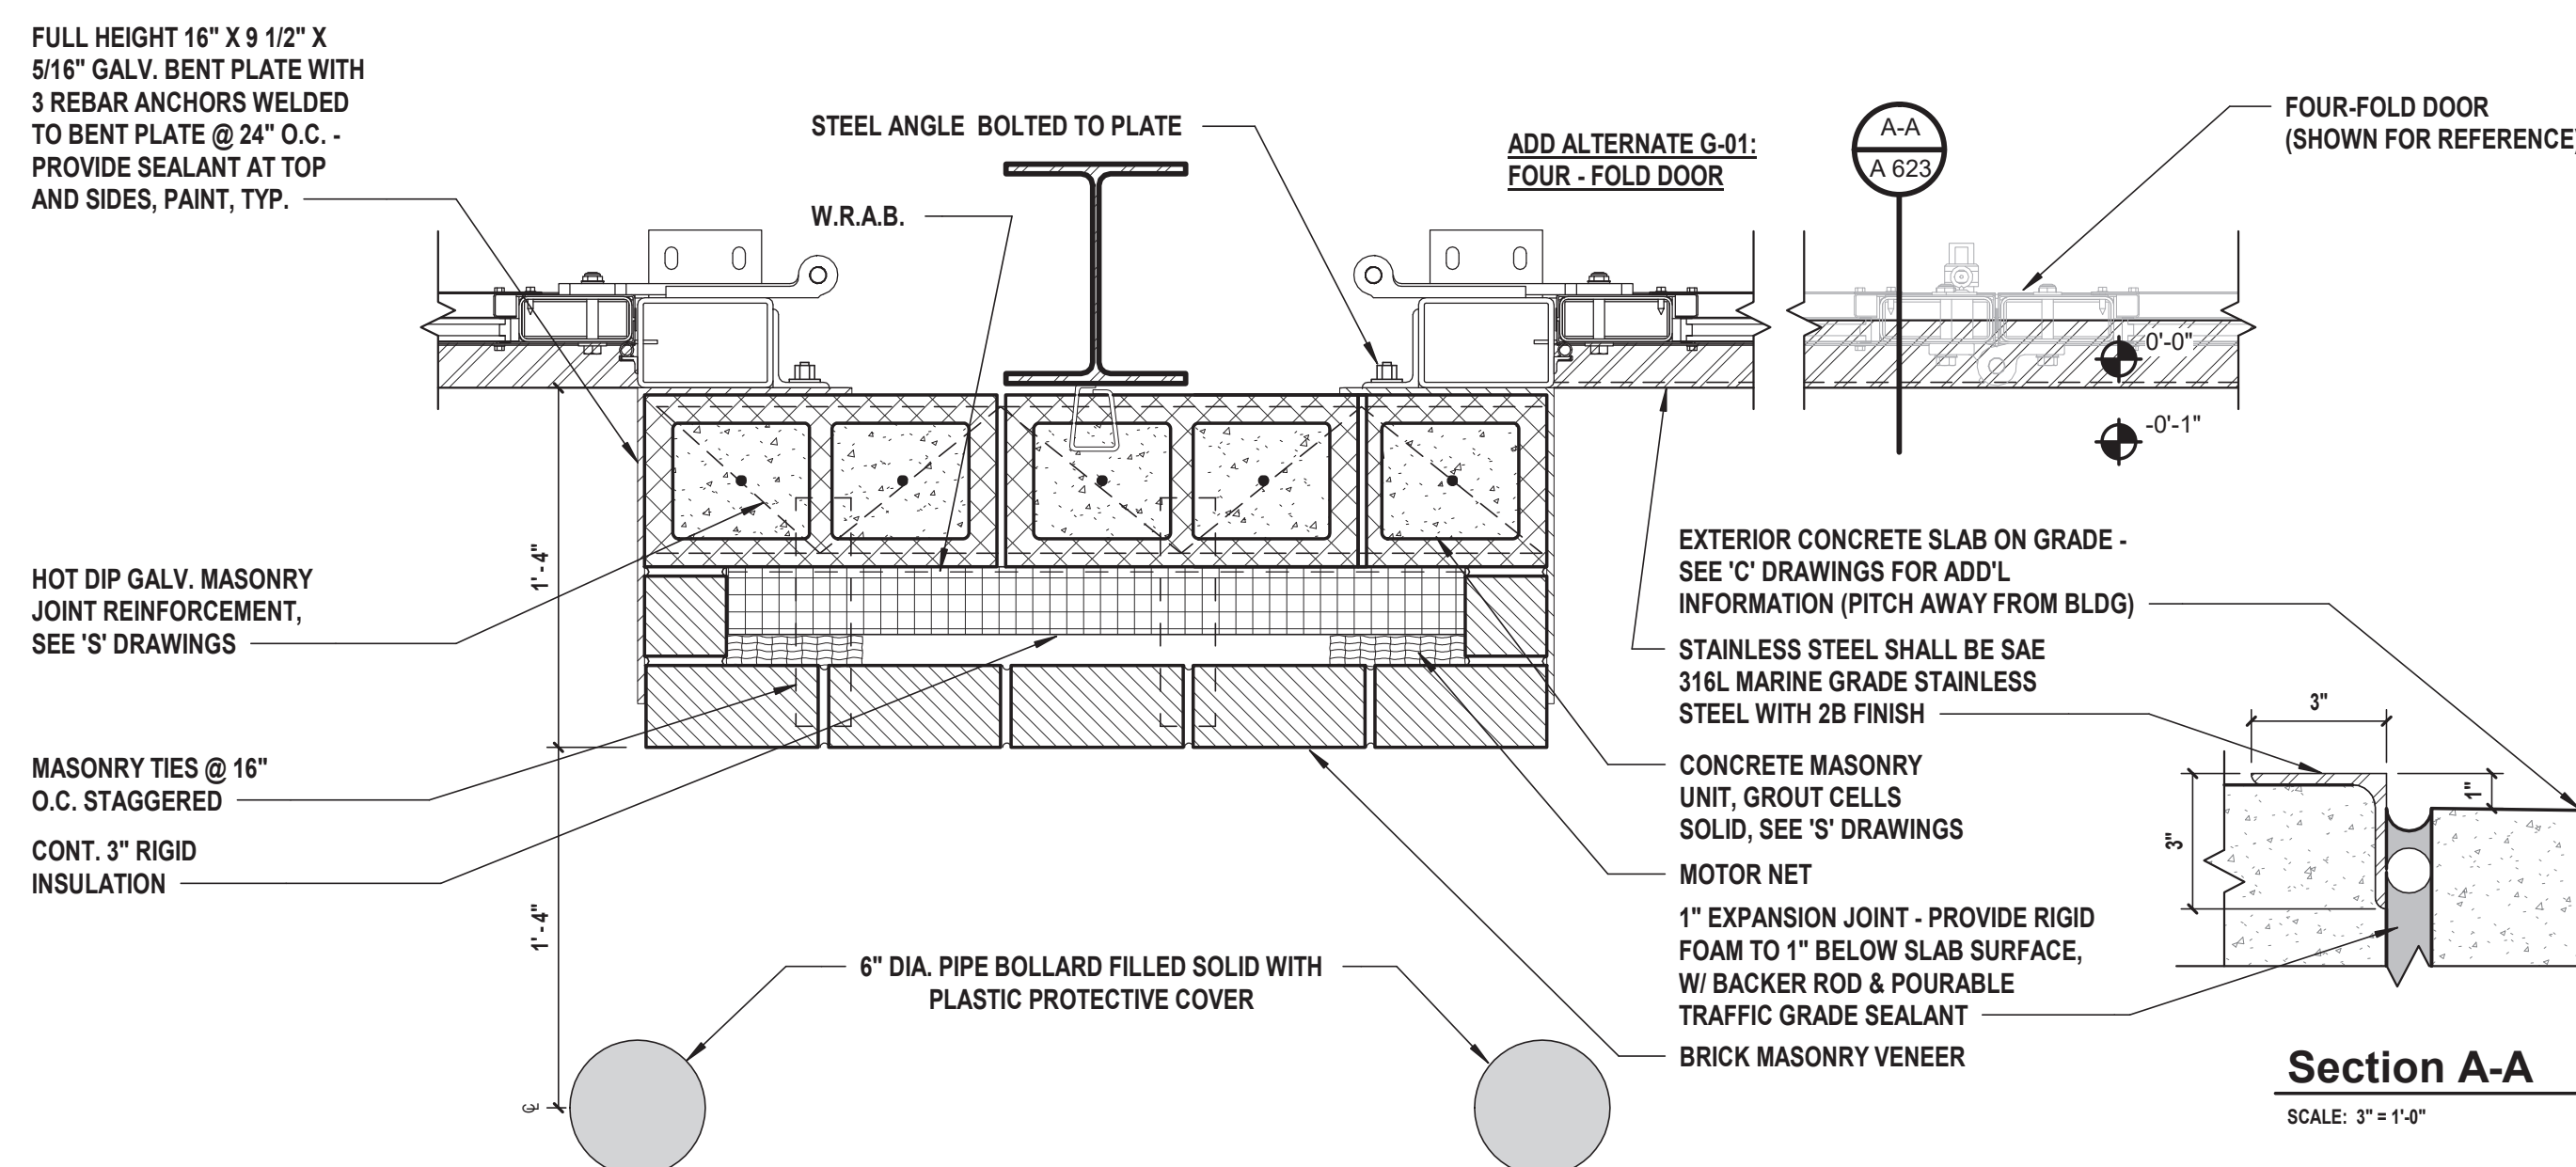


8 Fold Door Jamb Detail (Alternate G-01)
SCALE: 1 1/2" = 1'-0"

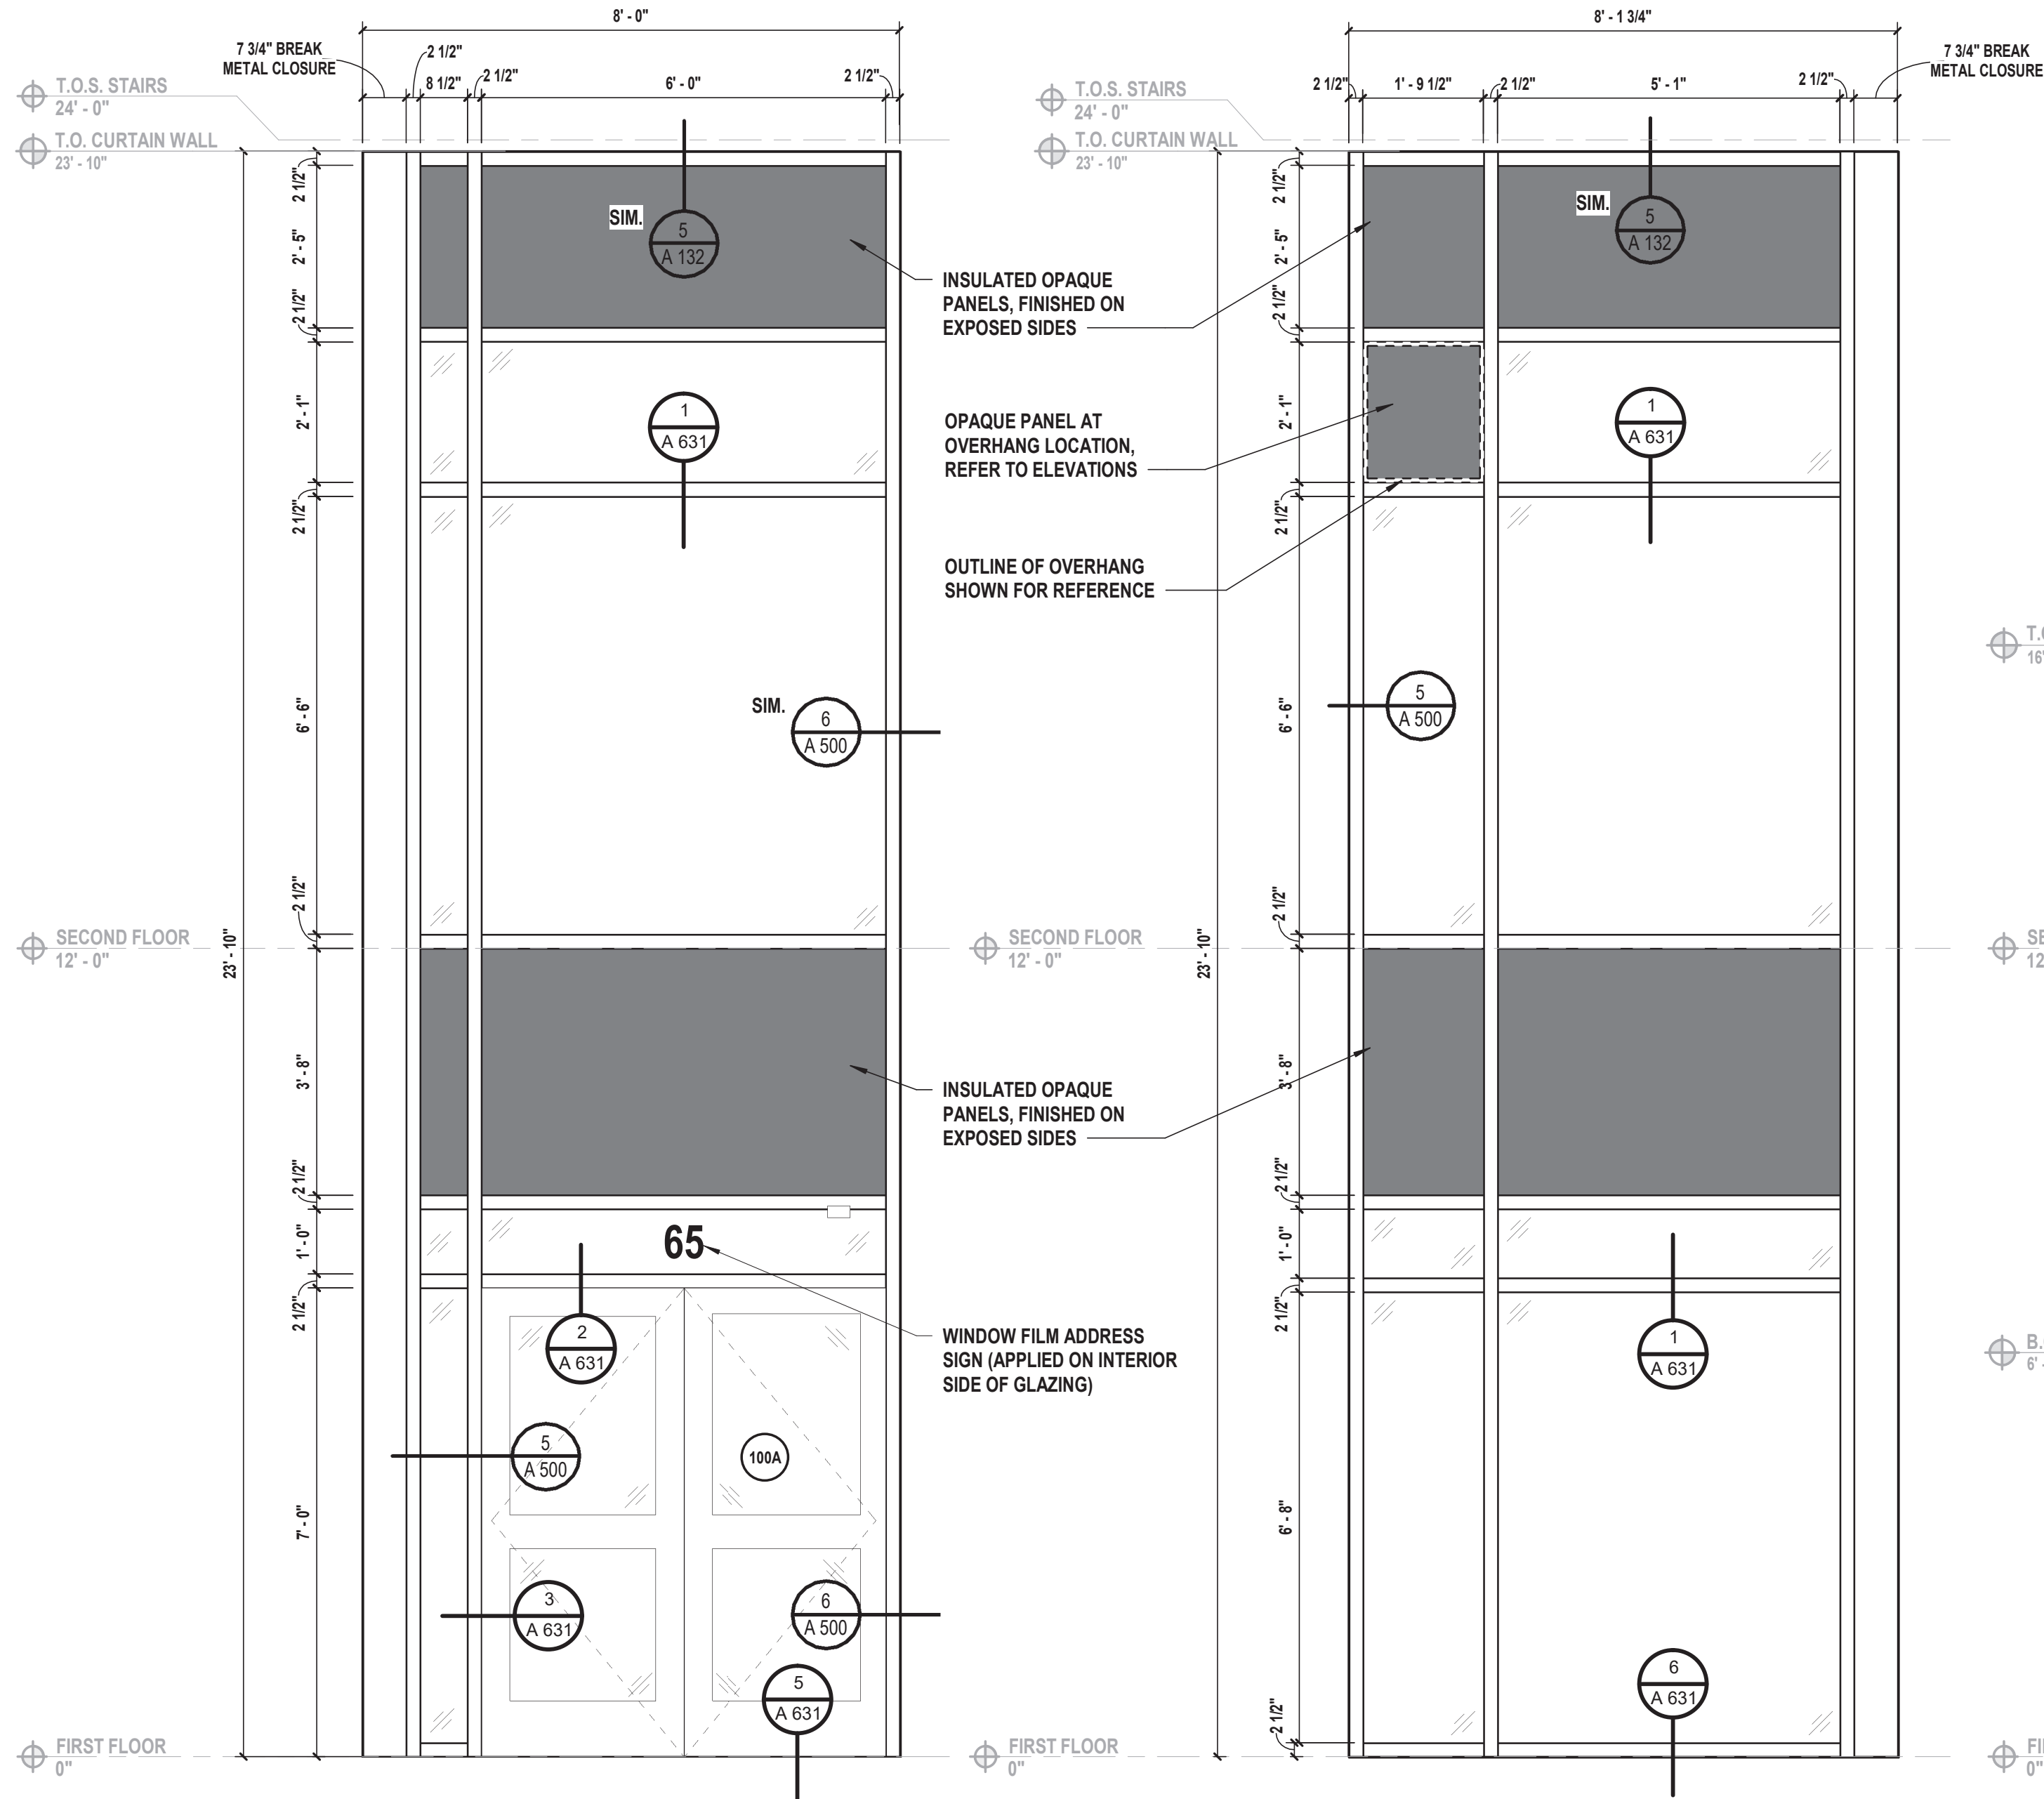


G Curtain Wall Type G
SCALE: 1/2" = 1'-0"


H Curtain Wall Type H
SCALE: 1/2" = 1'-0"

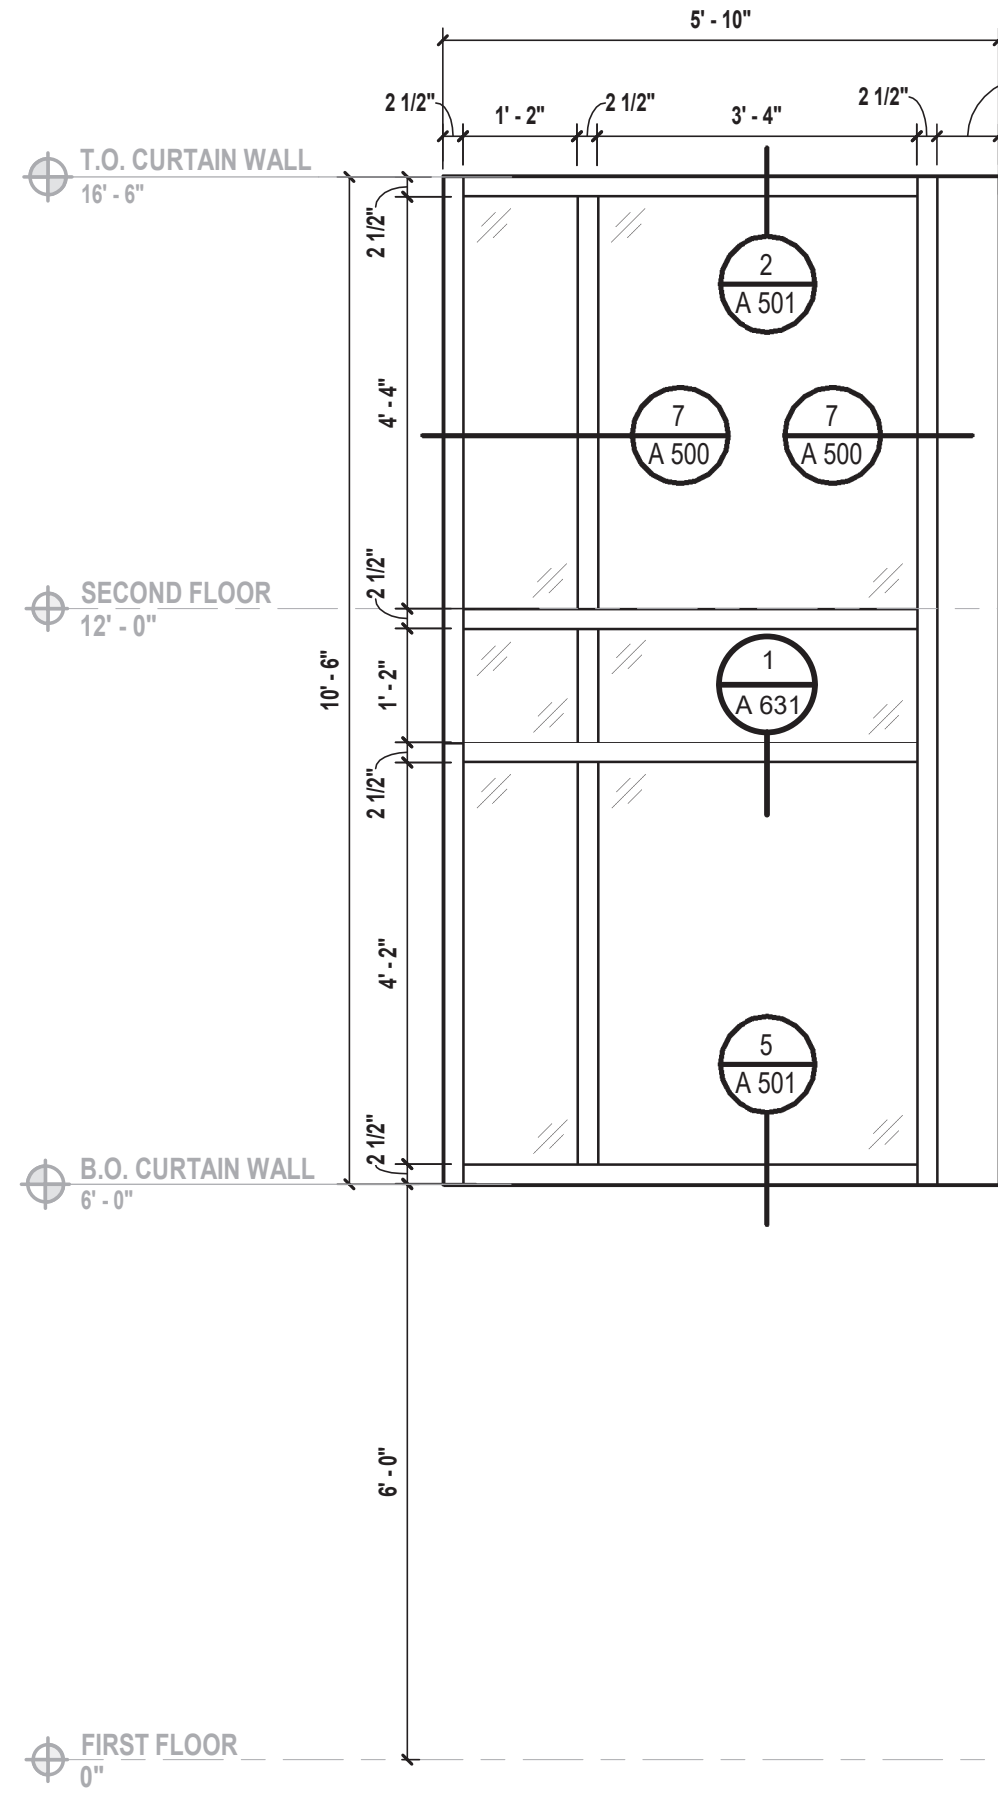


I Curtain Wall Type I
SCALE: 1/2" = 1'-0"

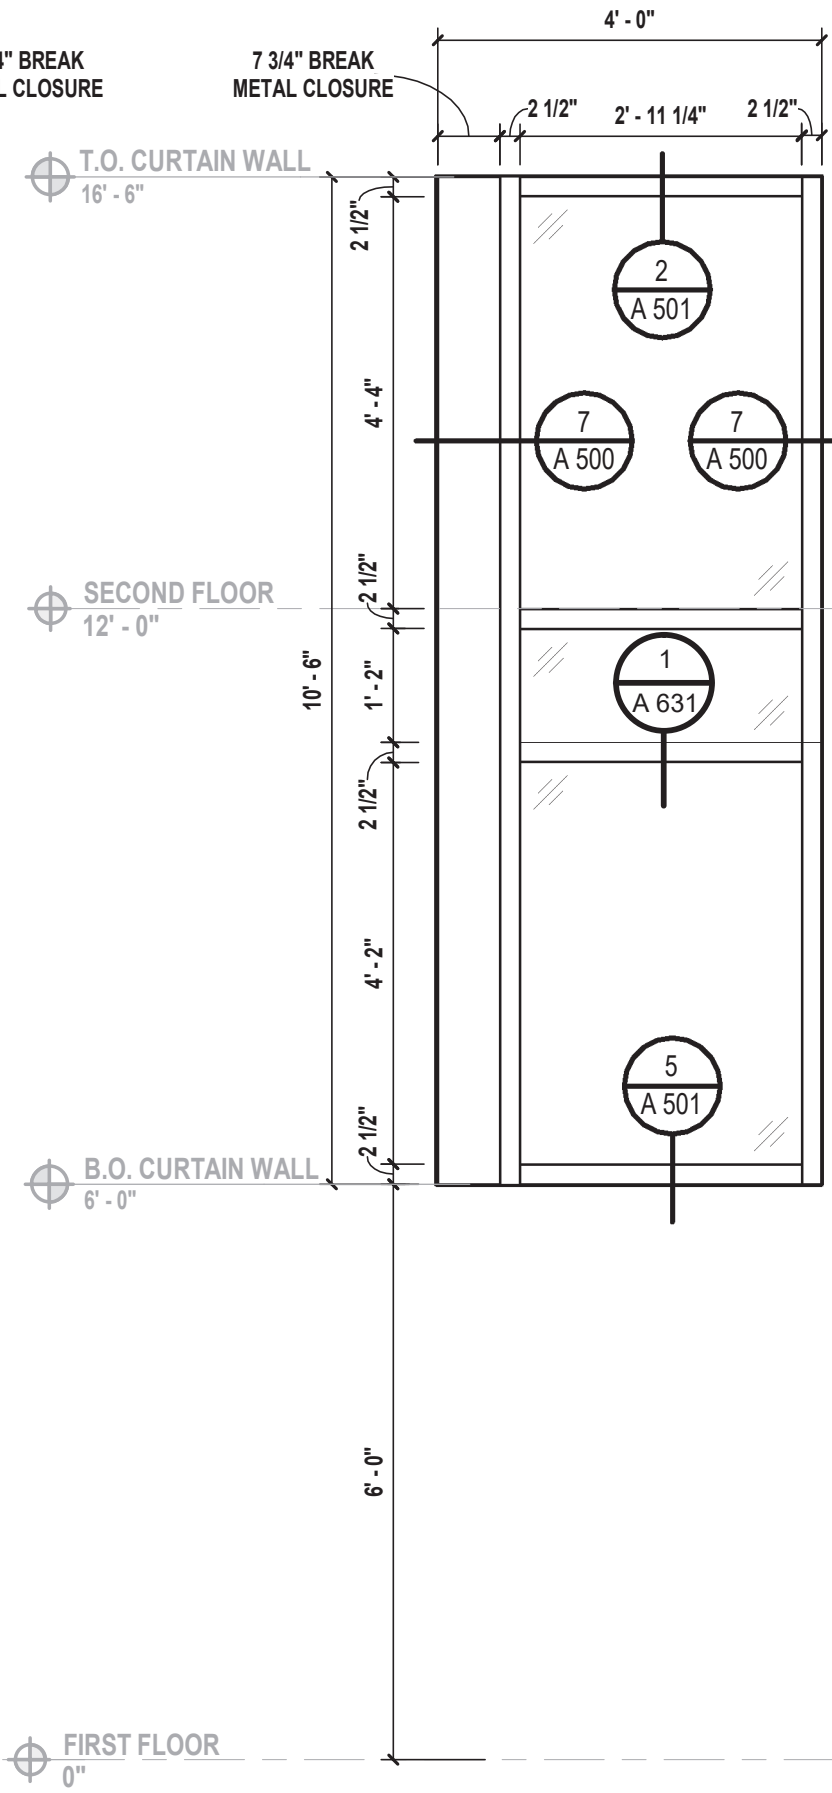

J Curtain Wall Type J
SCALE: 1/2" = 1'-0"

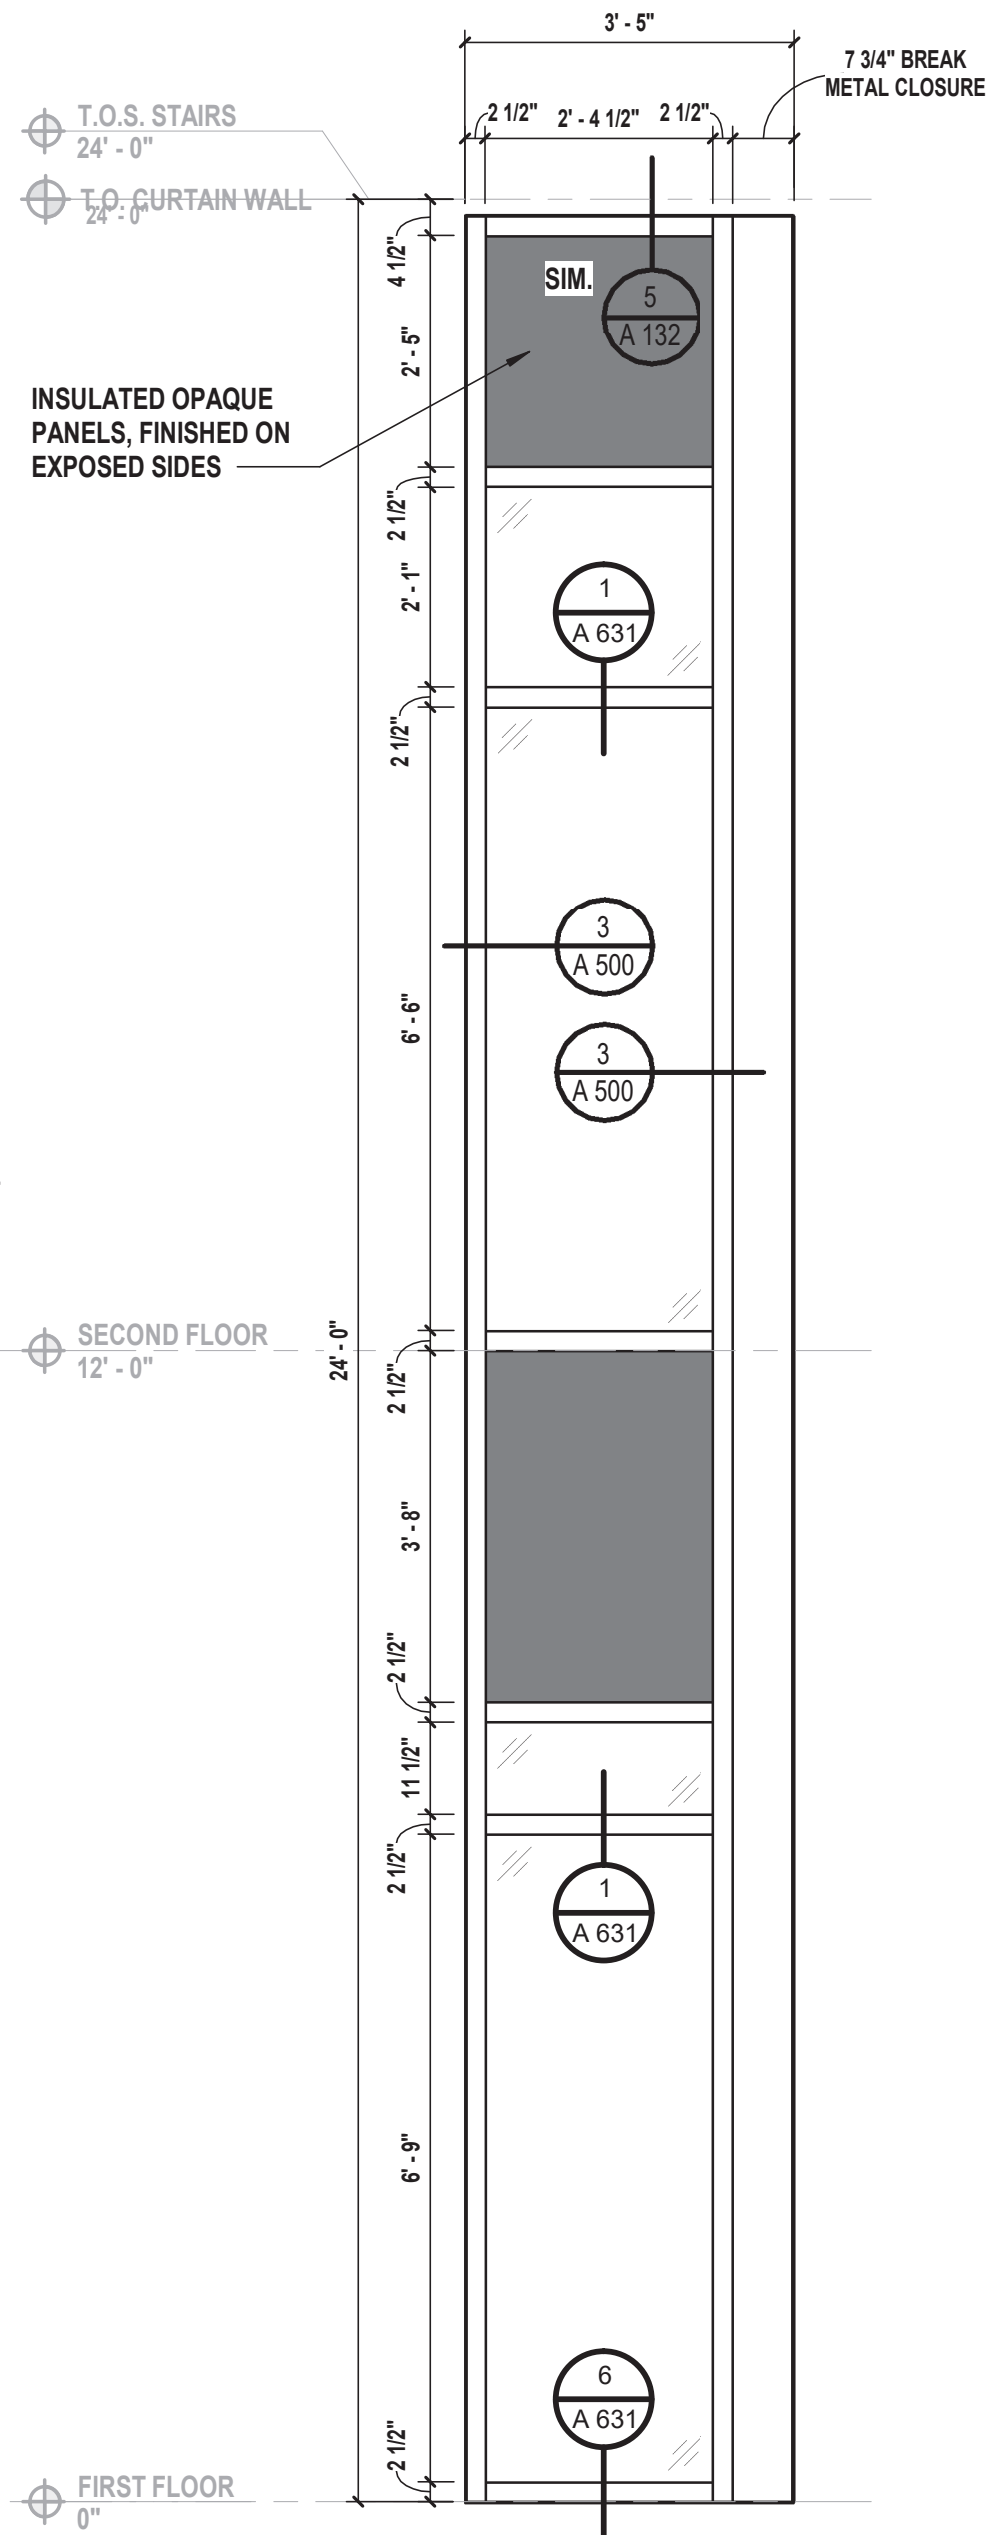

K Curtain Wall Type K
SCALE: 1/2" = 1'-0"

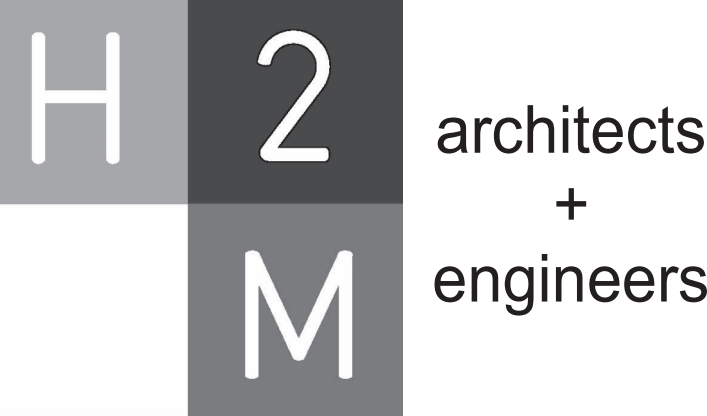

538 Broad Hollow Road, 4th Floor East
Melville, NY 11747
631.756.8000 • www.h2m.com
NY Architecture & Landscape Architecture: No Certificate Required
NY Engineering Certificate of Authorization No.: 0018178

CONSULTANTS:		

MARK	DATE	DESCRIPTION

Patrick O. Stone
PATRICK O. STONE, R.A.
NY PROFESSIONAL ARCHITECT LIC. NO. 039654
10/31/2025
Exp. Date

*IN ACCORDANCE WITH ARTICLE 145, SECTION 1209 OF THE NYS EDUCATION LAW, ALTERNATION OF THIS DOCUMENT (EXCEPT BY A LICENSED PROFESSIONAL) IS ILLEGAL.

DESIGNED BY:	DRAWN BY:	CHECKED BY:	REVIEWED BY:
DBS/RLG	KAP	DBS	POS
PROJECT No:	DATE:	SCALE:	
TRFD 2302	FEBRUARY 2025	AS SHOWN	

CLIENT

**THIELLS
ROSEVILLE FIRE
DISTRICT**

**NEW 26-100 FIRE
HEADQUARTERS**

**65 W RAMAPO ROAD
GARNERVILLE, NY 10923**

CONTRACT
**CONTRACT G
GENERAL CONSTRUCTION**

STATUS
FINAL BID DOCUMENT

SHEET TITLE
CURTAIN WALL TYPES

DRAWING No.
A 630.00

CONSULTANTS:		

MARK	DATE	DESCRIPTION


REGISTERED ARCHITECT
PATRICK O. STONE
STATE OF NEW YORK
039654


PATRICK O. STONE, R.A.
NY PROFESSIONAL ARCHITECT LIC. NO. 039654


10/31/2025
Exp. Date

"IN ACCORDANCE WITH ARTICLE 145, SECTION 1209 OF THE NYS EDUCATION LAW,
ALTACTION OF THIS DOCUMENT EXCEPT BY A LICENSED PROFESSIONAL IS ILLEGAL."


DESIGNED BY:	DRAWN BY:	CHECKED BY:	REVIEWED BY:
DBS/RLG	KAP	DBS	POS
PROJECT No:	DATE:	SCALE:	AS SHOWN
TRFD 2302	FEBRUARY 2025		

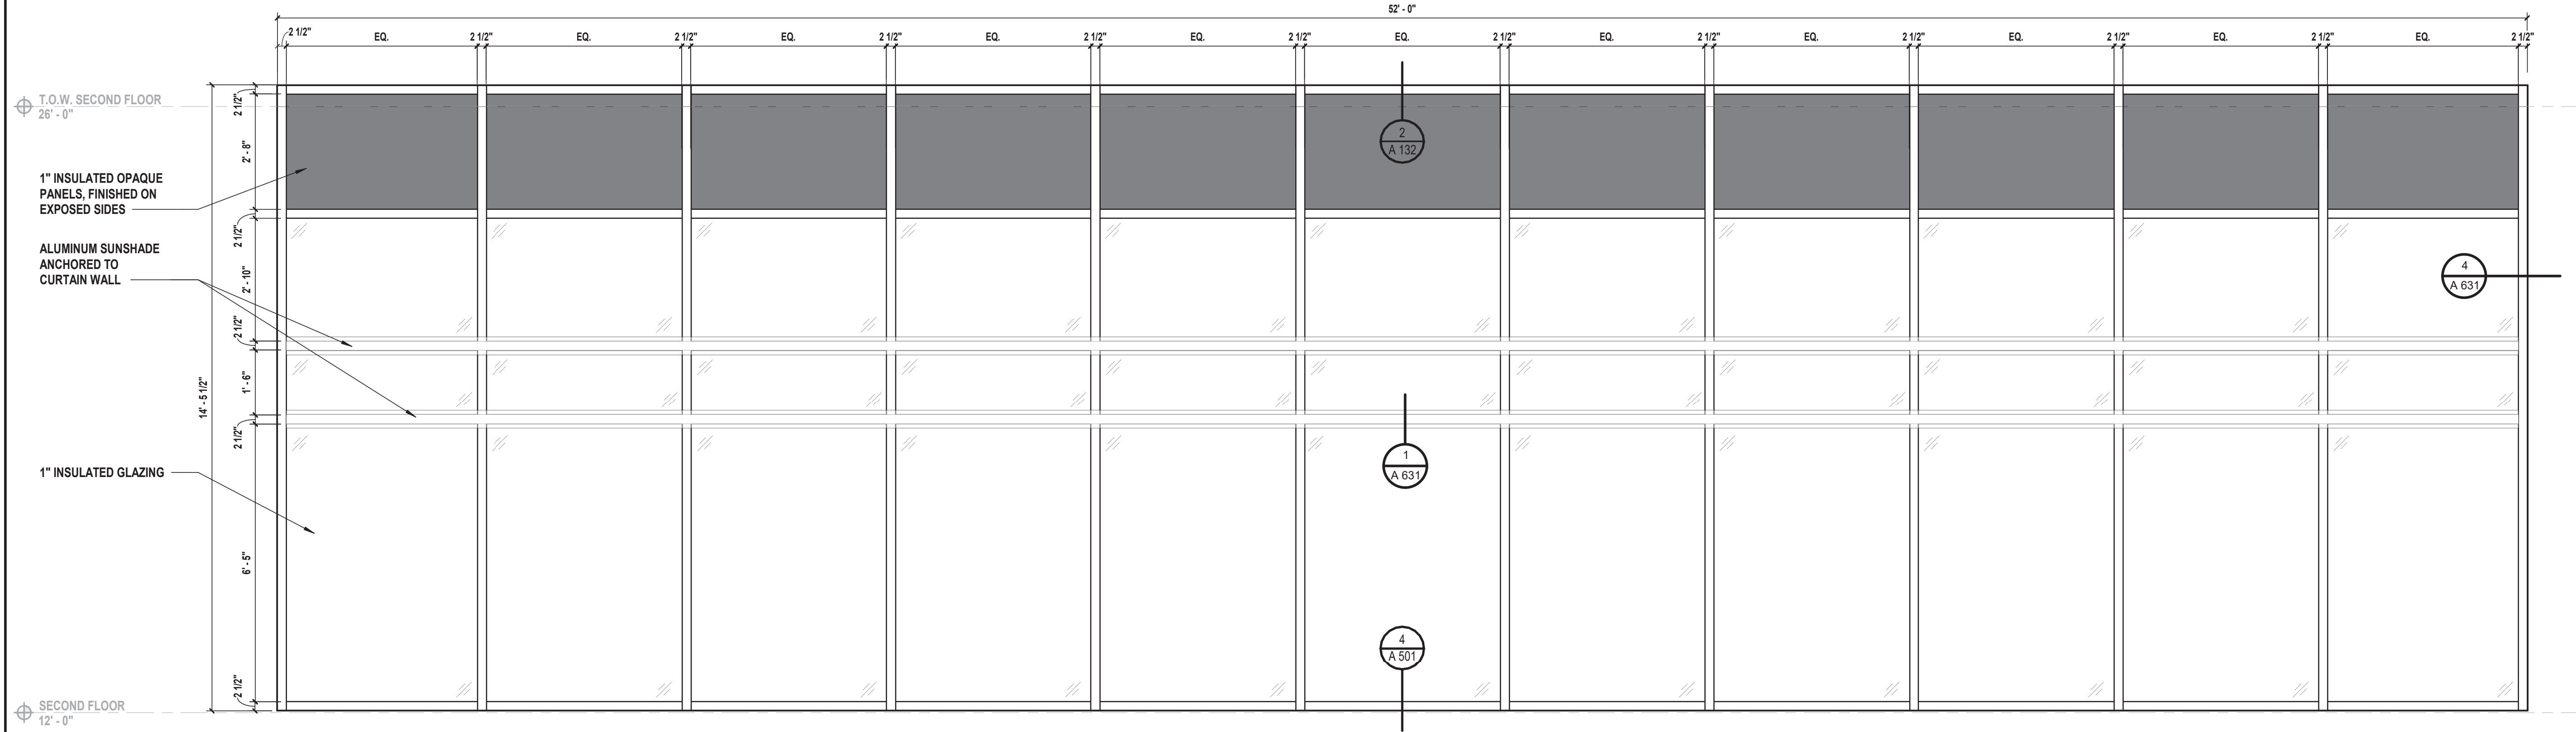


Curtain Wall Type L
SCALE: 1/2" = 1'-0"

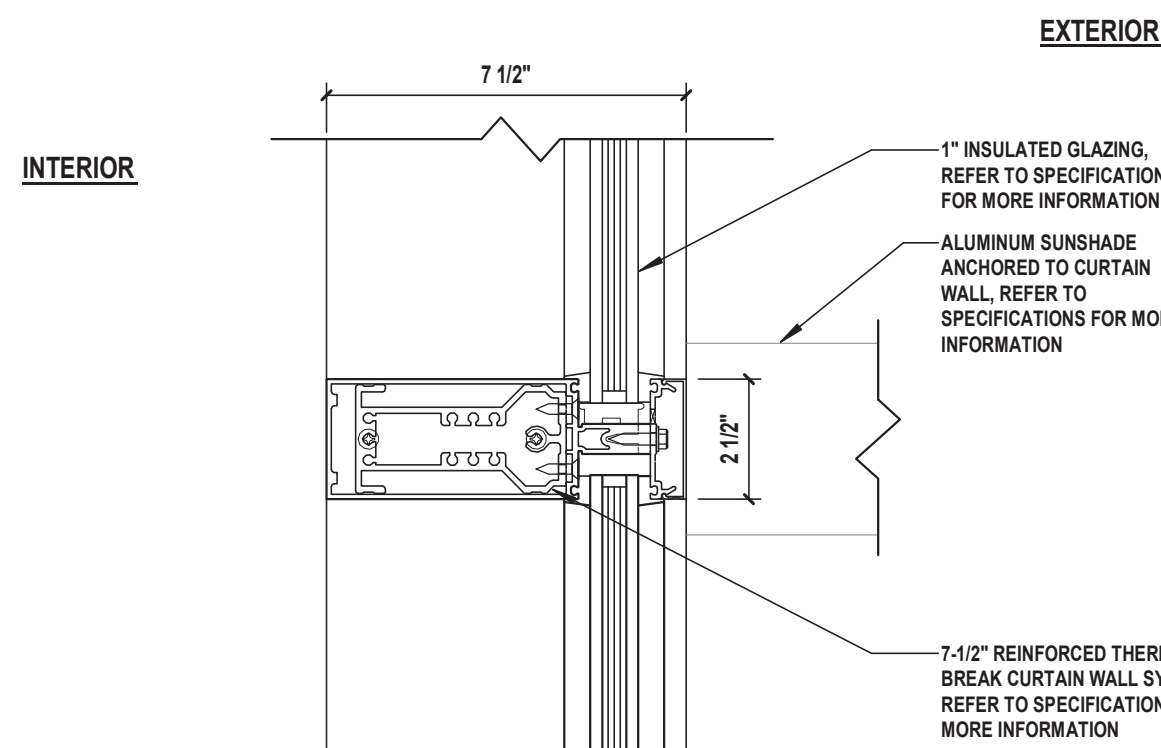


1 Horizontal Detail
SCALE: 3/4" = 1'-0"

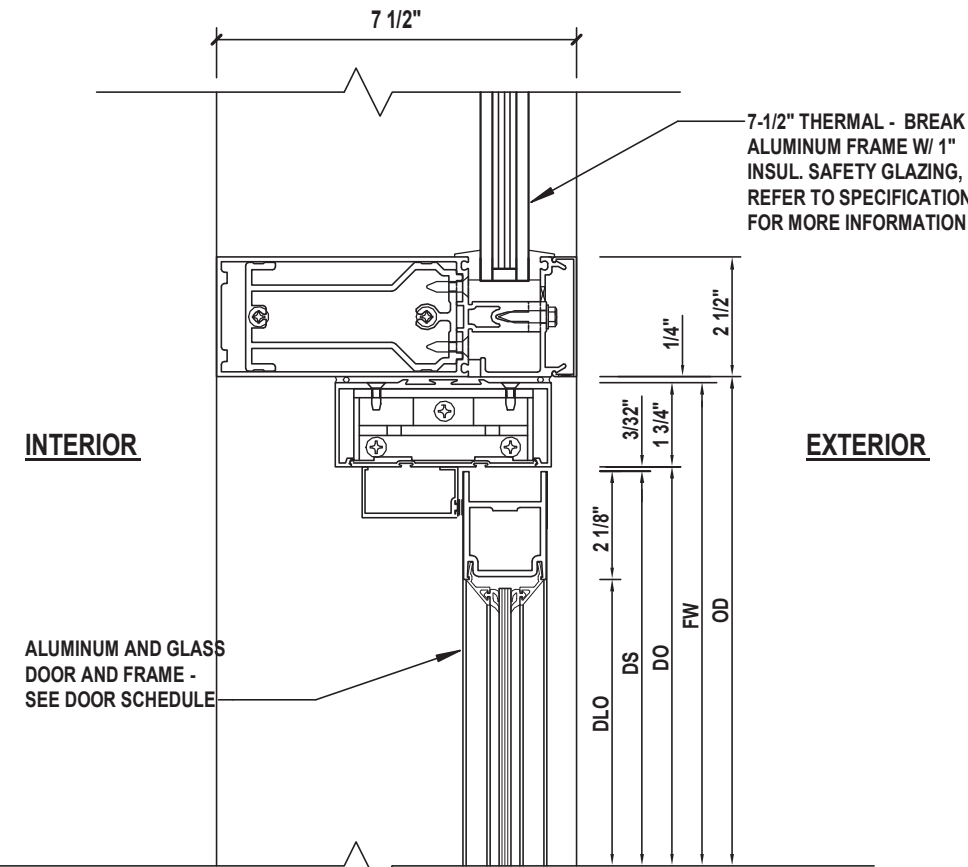


2 Door Head Detail
SCALE: 3/4" = 1'-0"

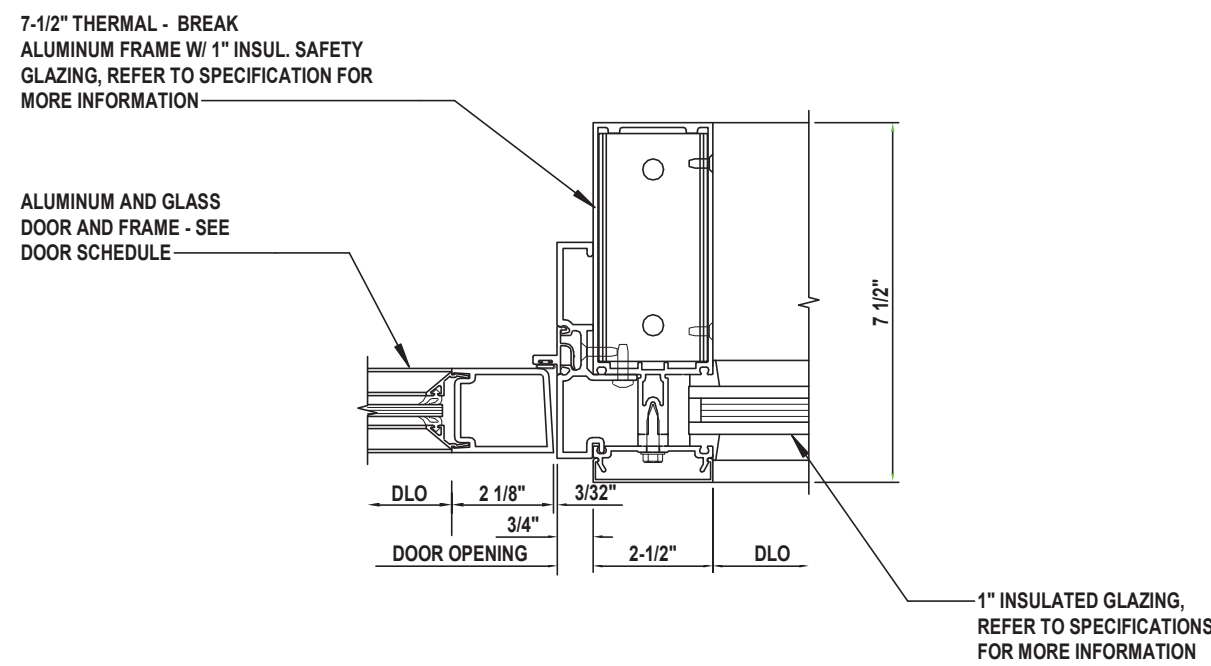


3 Door Jamb Detail
SCALE: 3/4" = 1'-0"

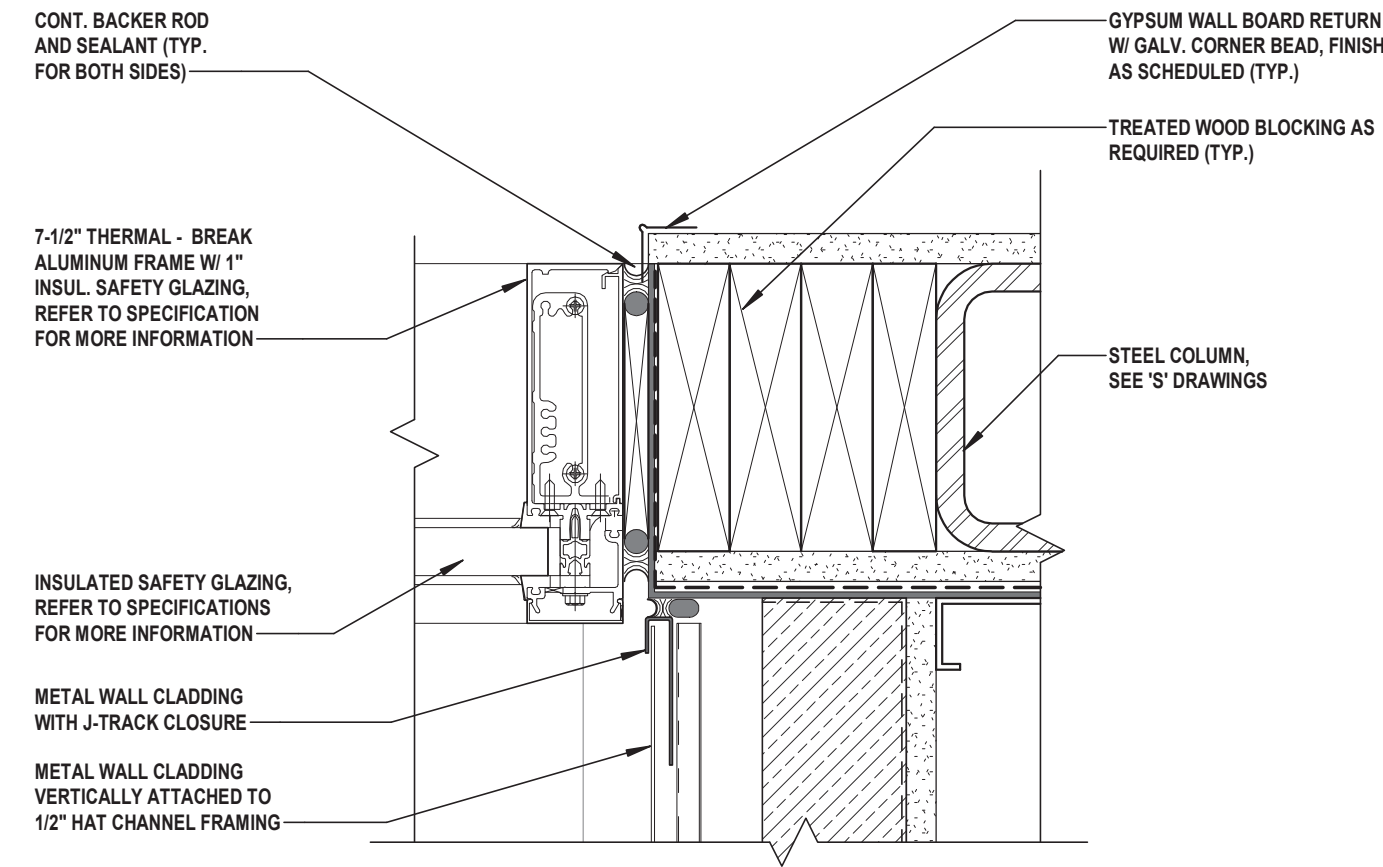

4 Curtain Wall Jamb
SCALE: 3/4" = 1'-0"

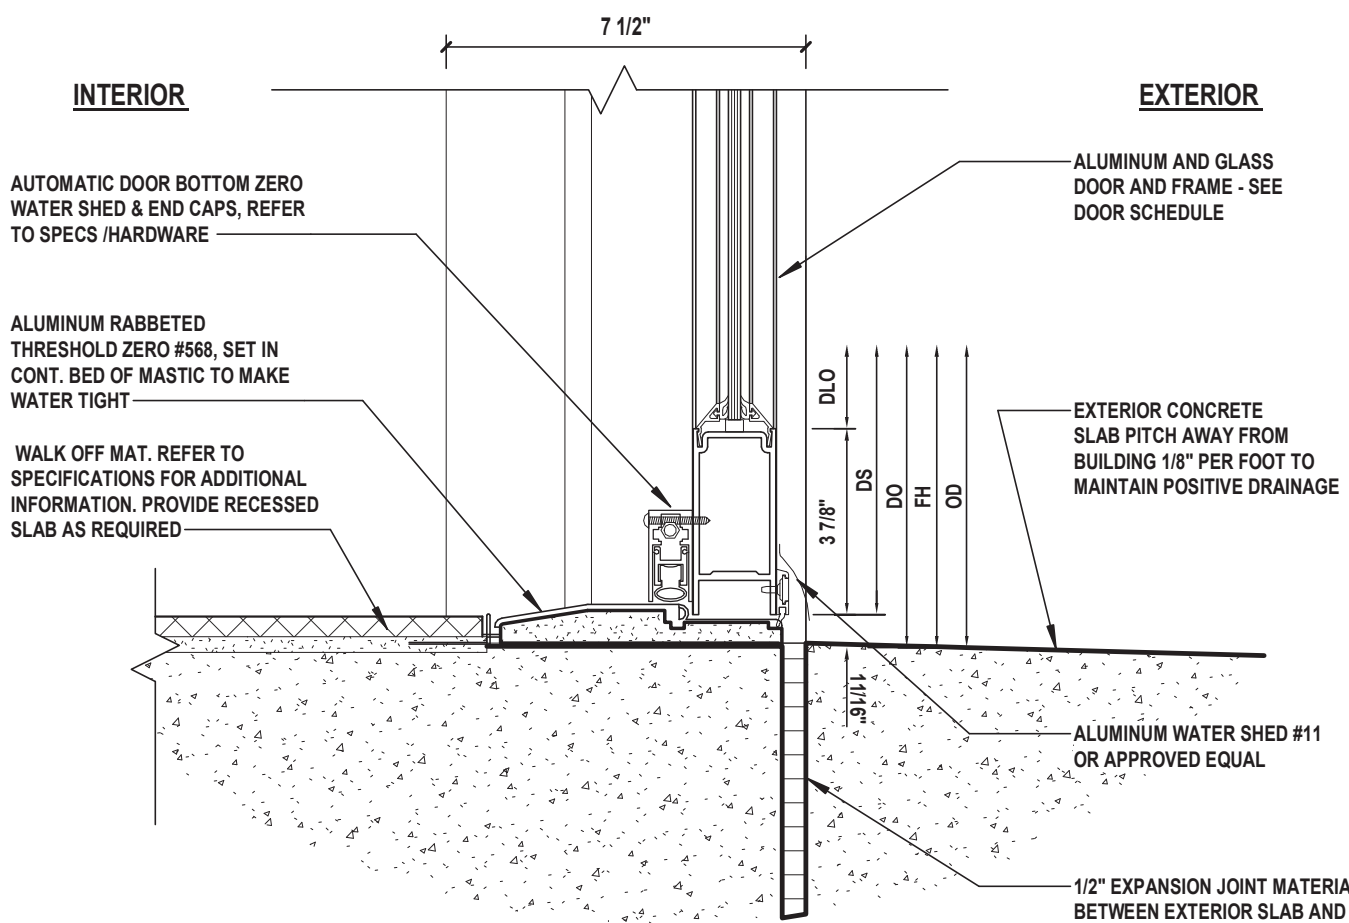

5 Door Threshold Detail
SCALE: 3/4" = 1'-0"

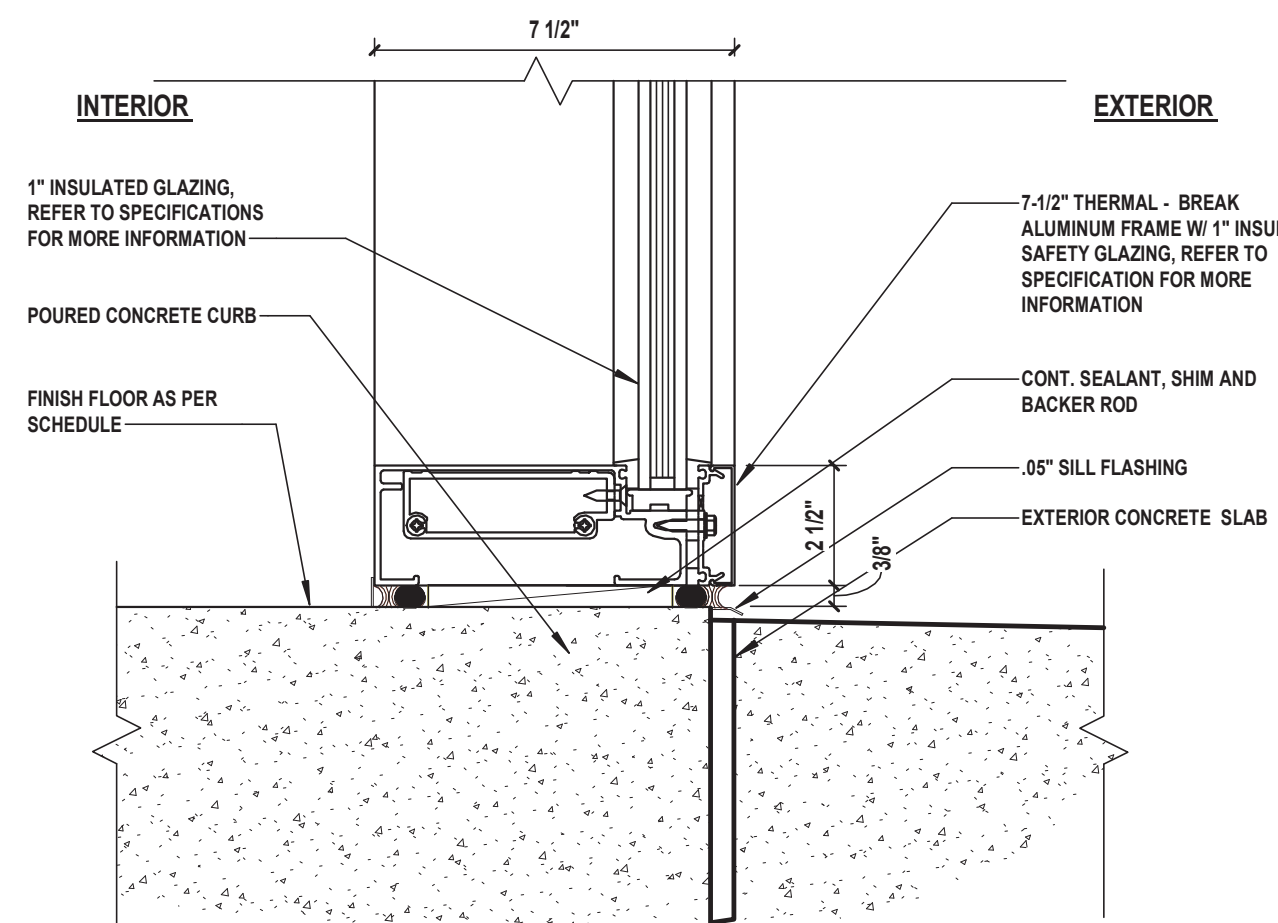

6 Curtain Wall Sill
SCALE: 3/4" = 1'-0"

CLIENT

**THIELLS
ROSEVILLE FIRE
DISTRICT**

NEW 26-100 FIRE
HEADQUARTERS



65 W RAMAPO ROAD
GARNERVILLE, NY 10923

CONTRACT

**CONTRACT G
GENERAL CONSTRUCTION**

STATUS


FINAL BID DOCUMENT

SHEET TITLE

CURTAIN WALL TYPES & DETAILS

DRAWING No.

A 631.00

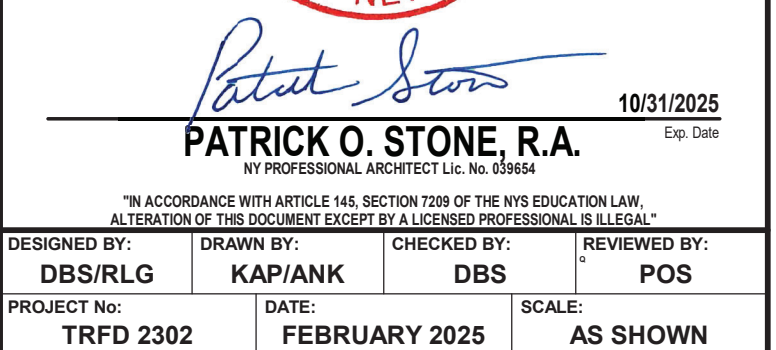[illegible]

 
 
 
 
 
65 W RAMAPO ROAD
GARNERVILLE, NY 10923


**CONTRACT G
GENERAL CONSTRUCTION**

FINAL BID DOCUMENT


STOREFRONT TYPES

A 640.00




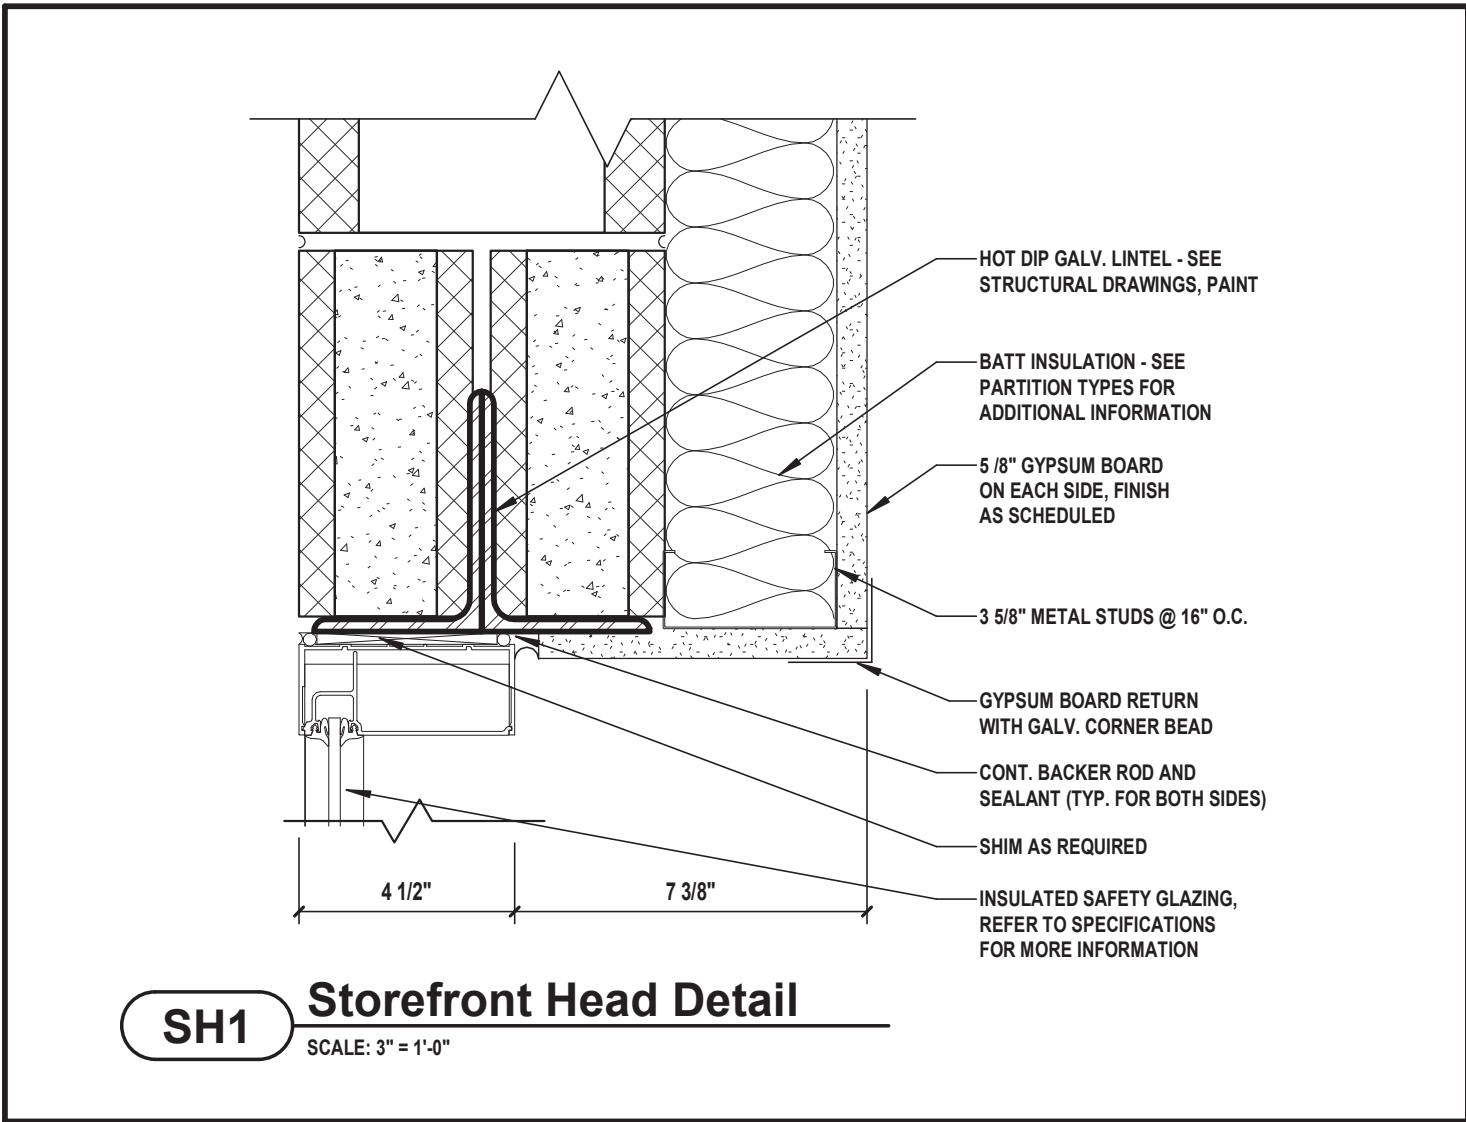


SH1 Storefront Head Detail

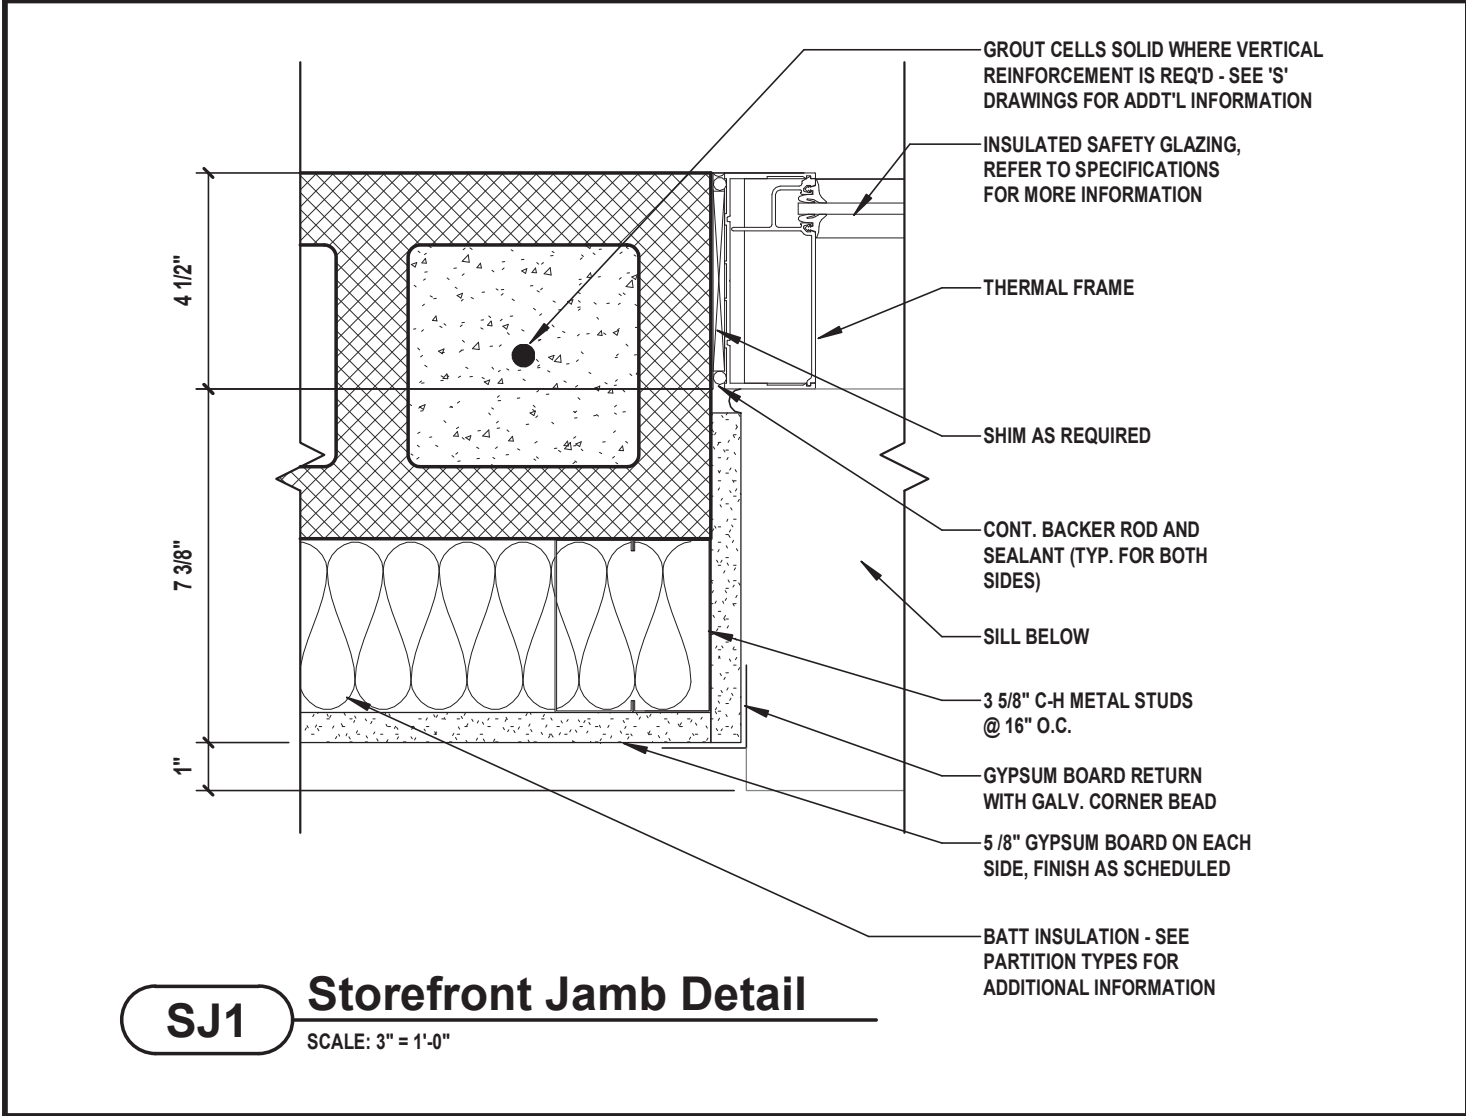


SJ1 Storefront Jamb Detail

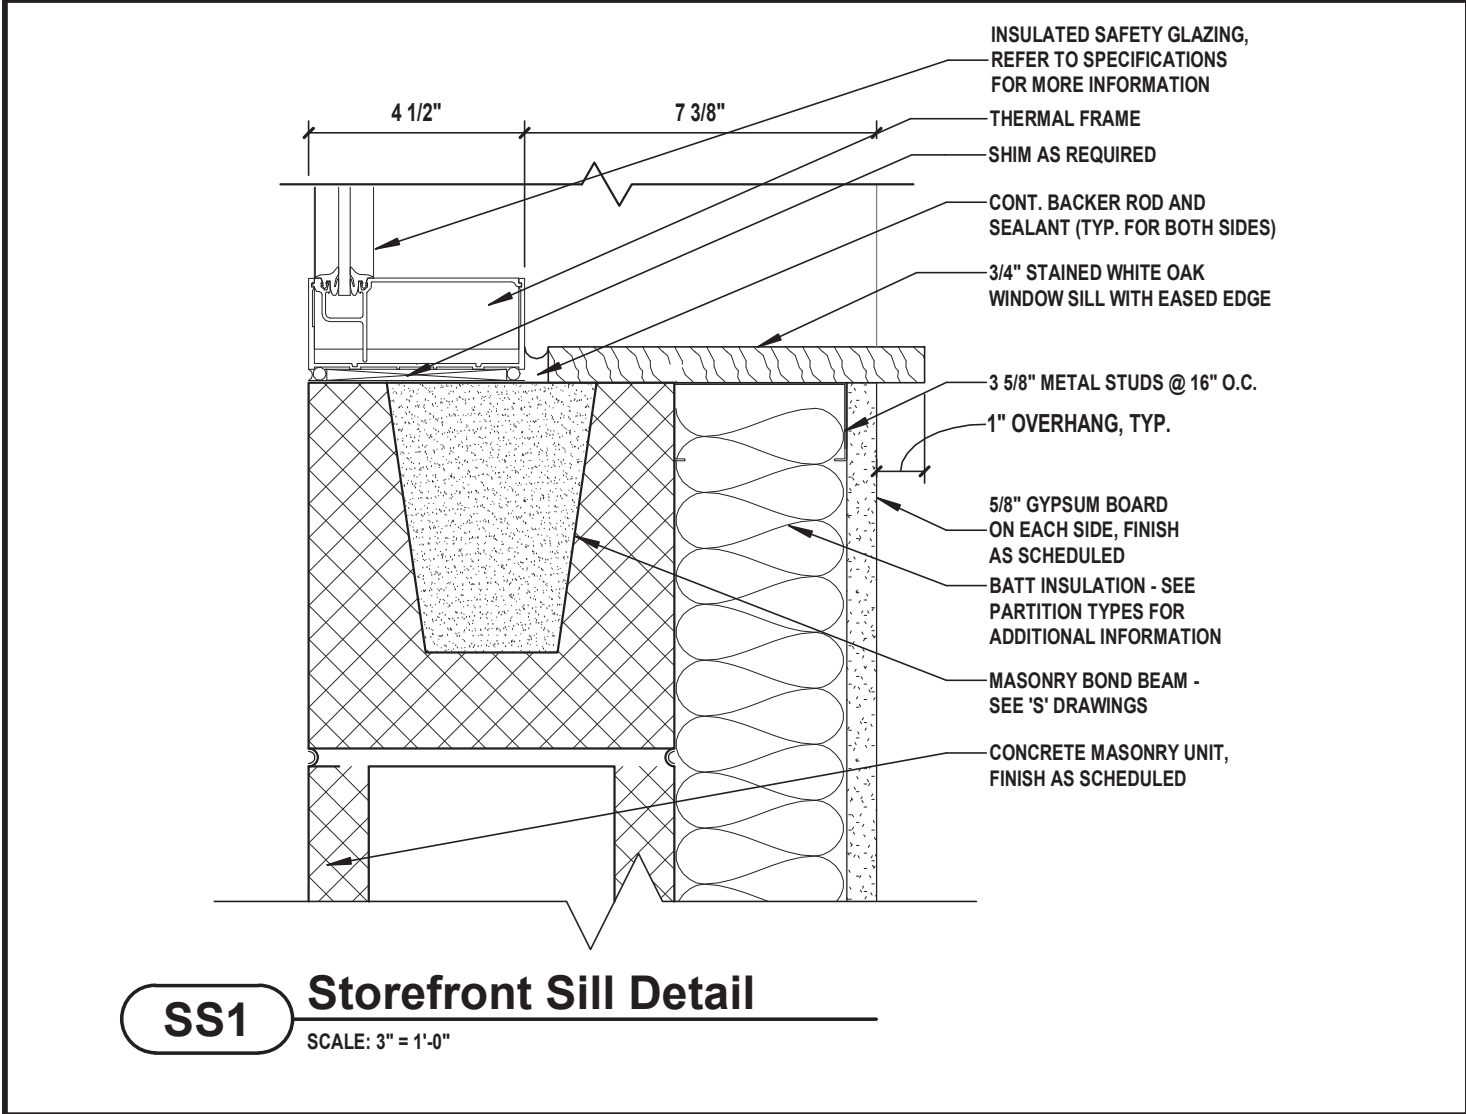


SS1 Storefront Sill Detail

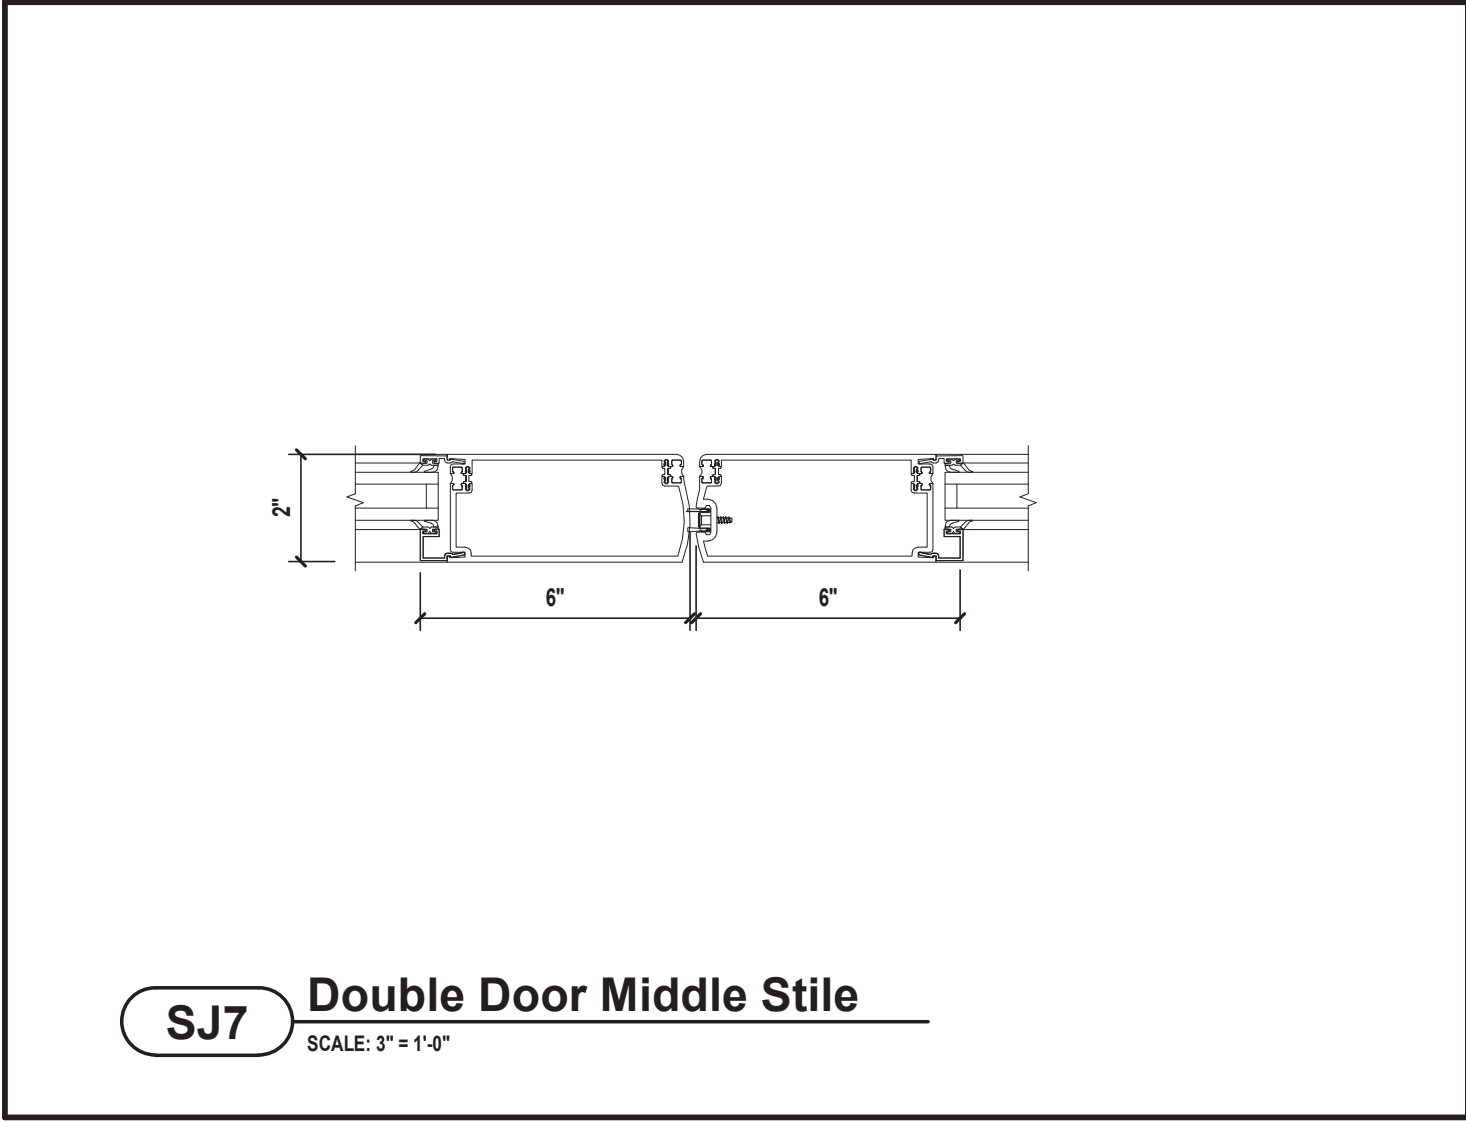


SJ7 Double Door Middle Stile

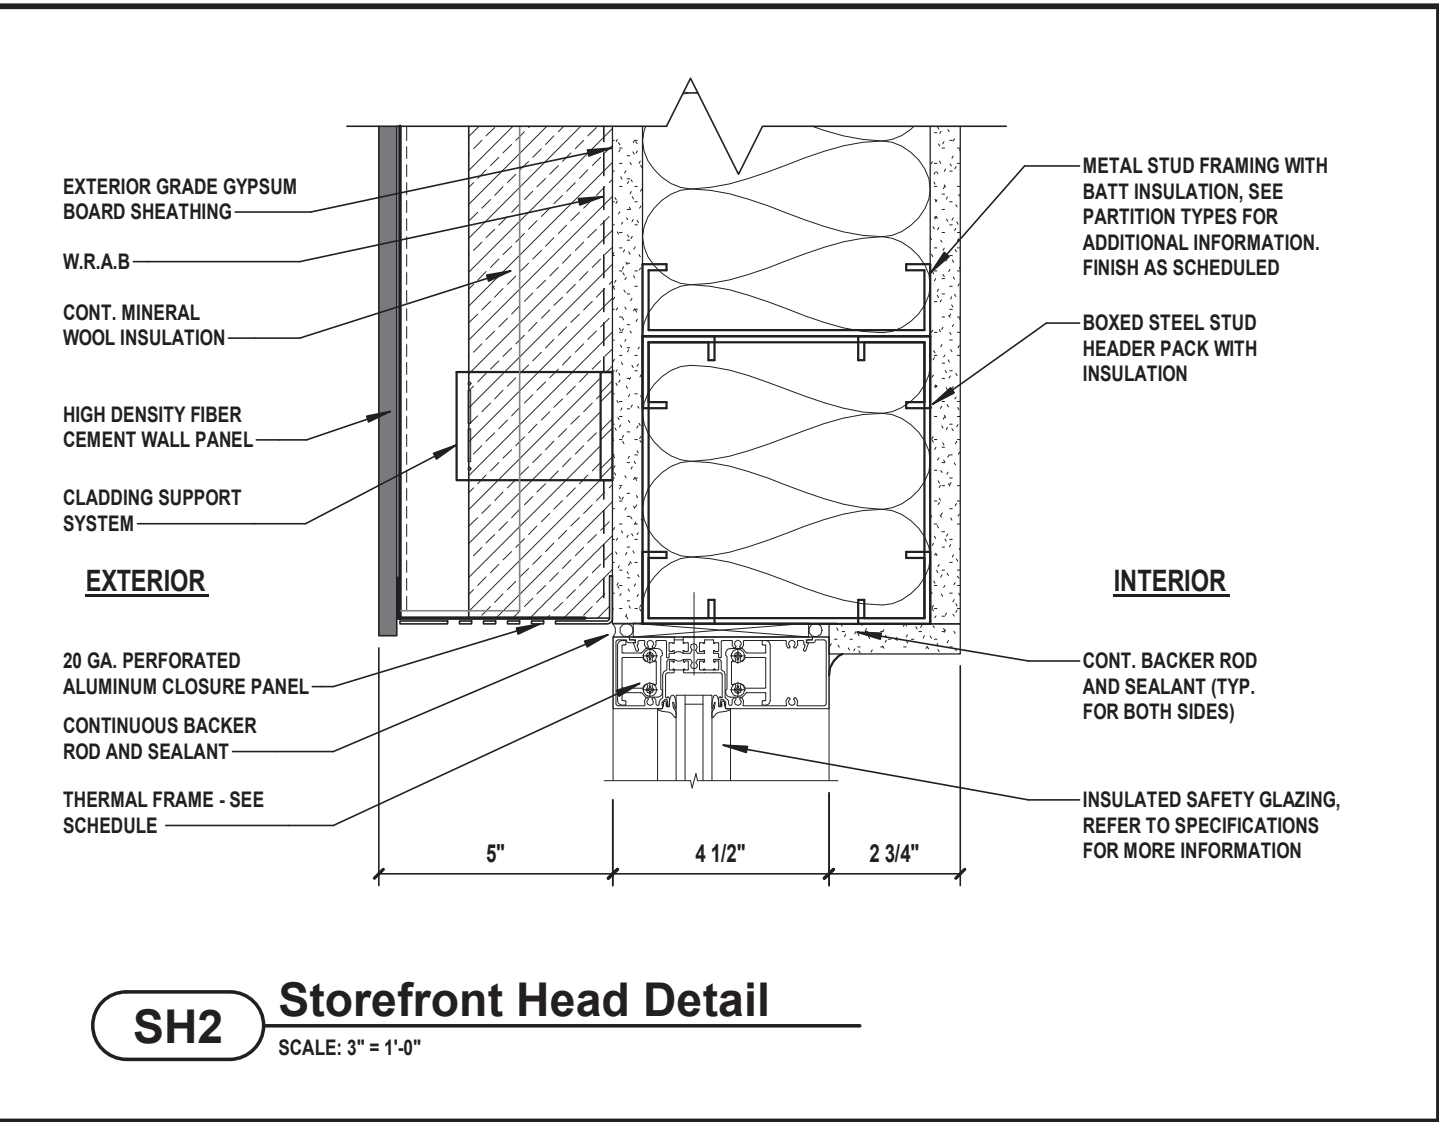


SH2 Storefront Head Detail

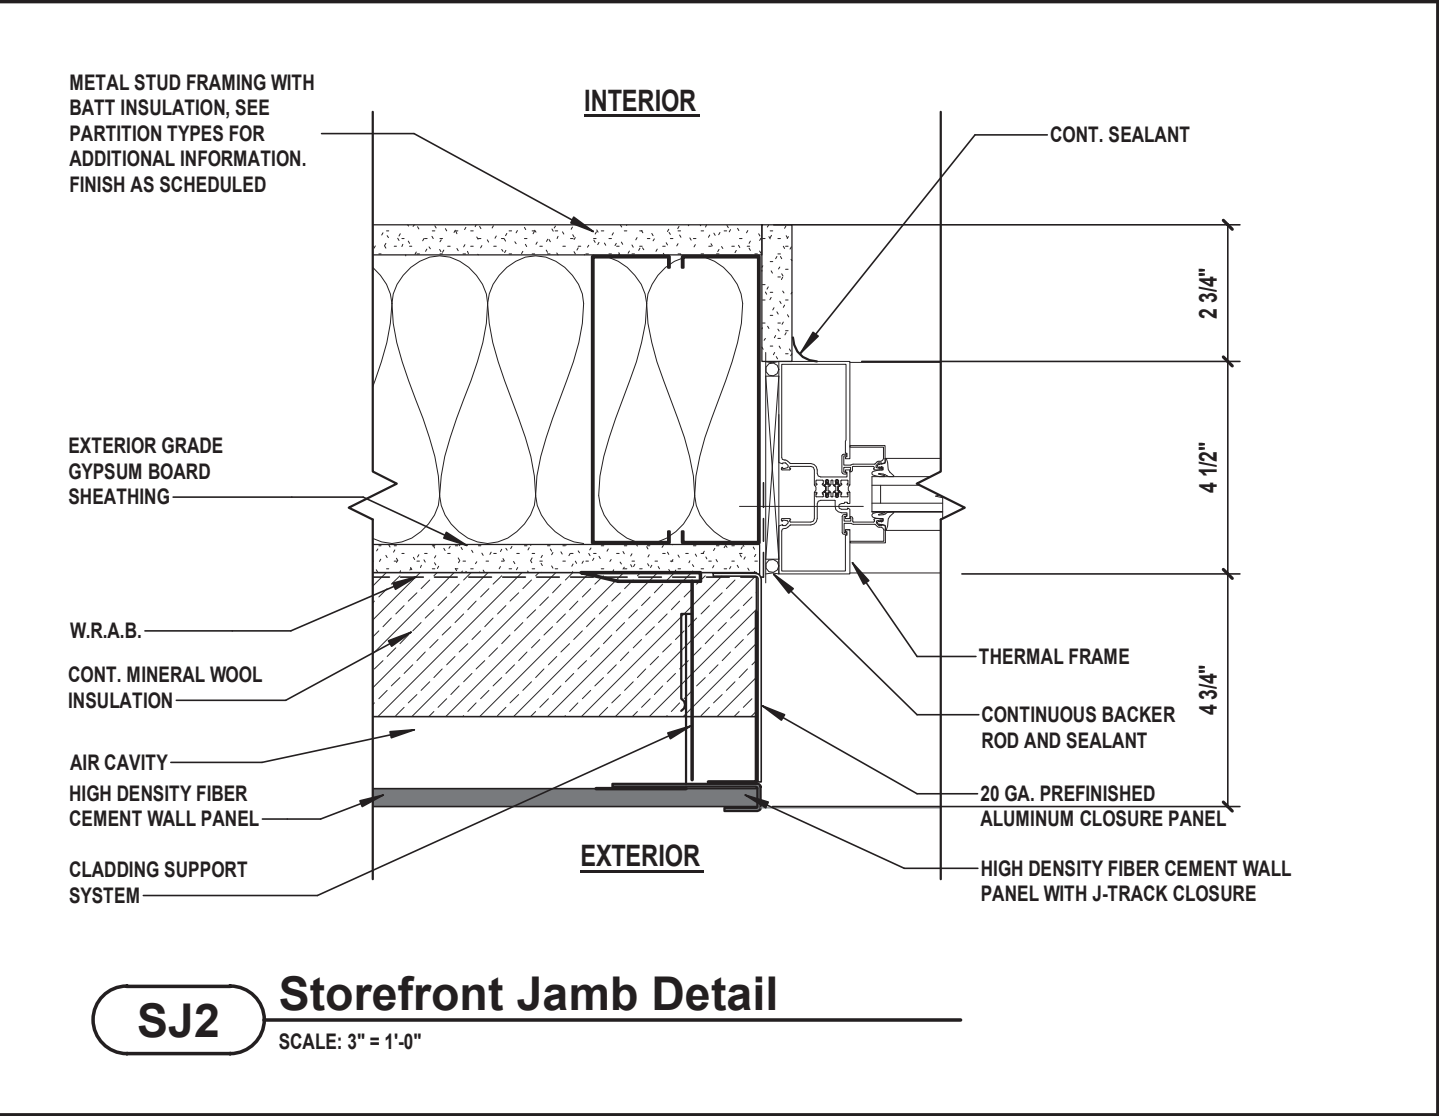


SJ2 Storefront Jamb Detail

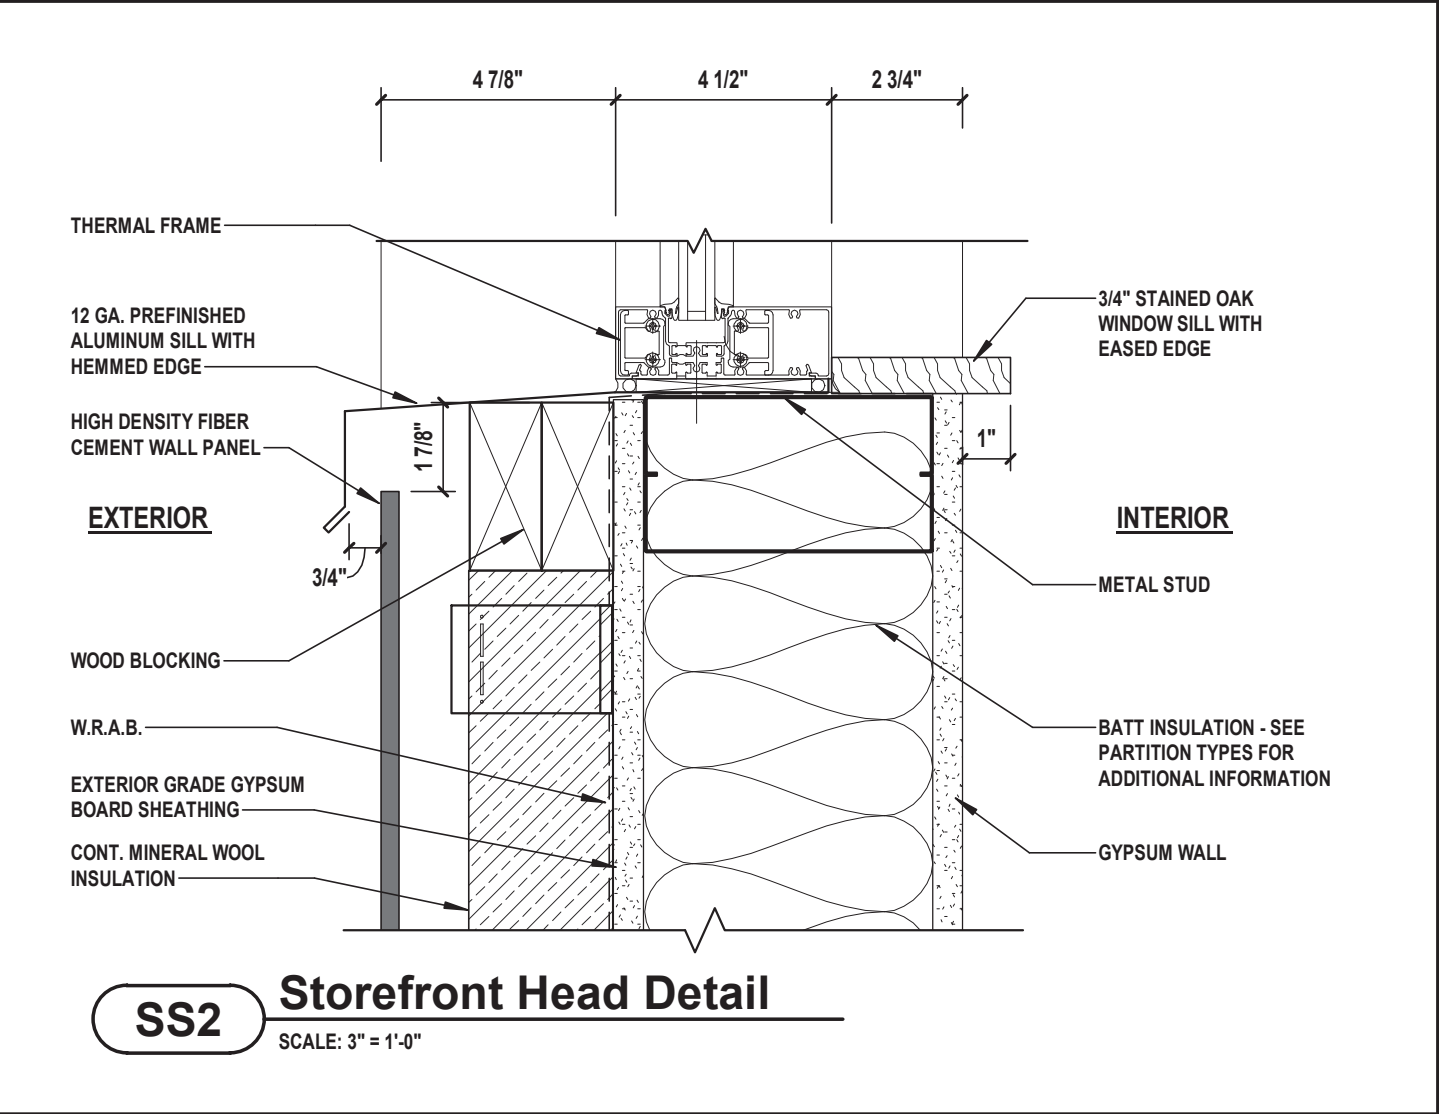


SS2 Storefront Head Detail

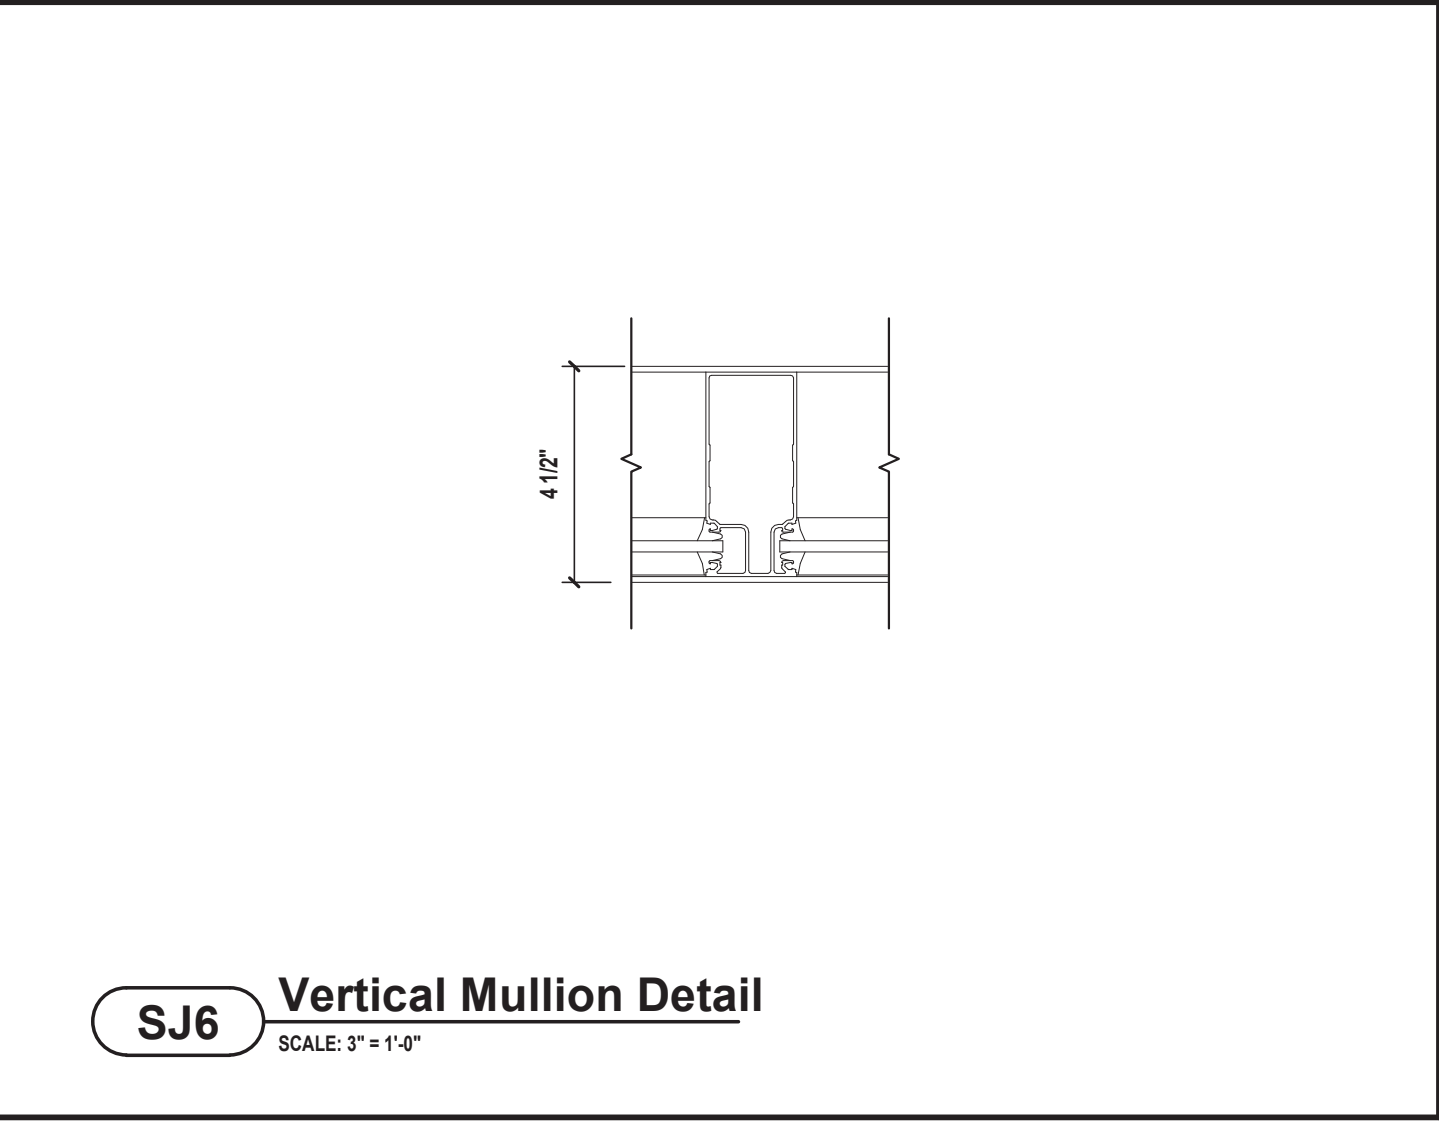


SJ6 Vertical Mullion Detail

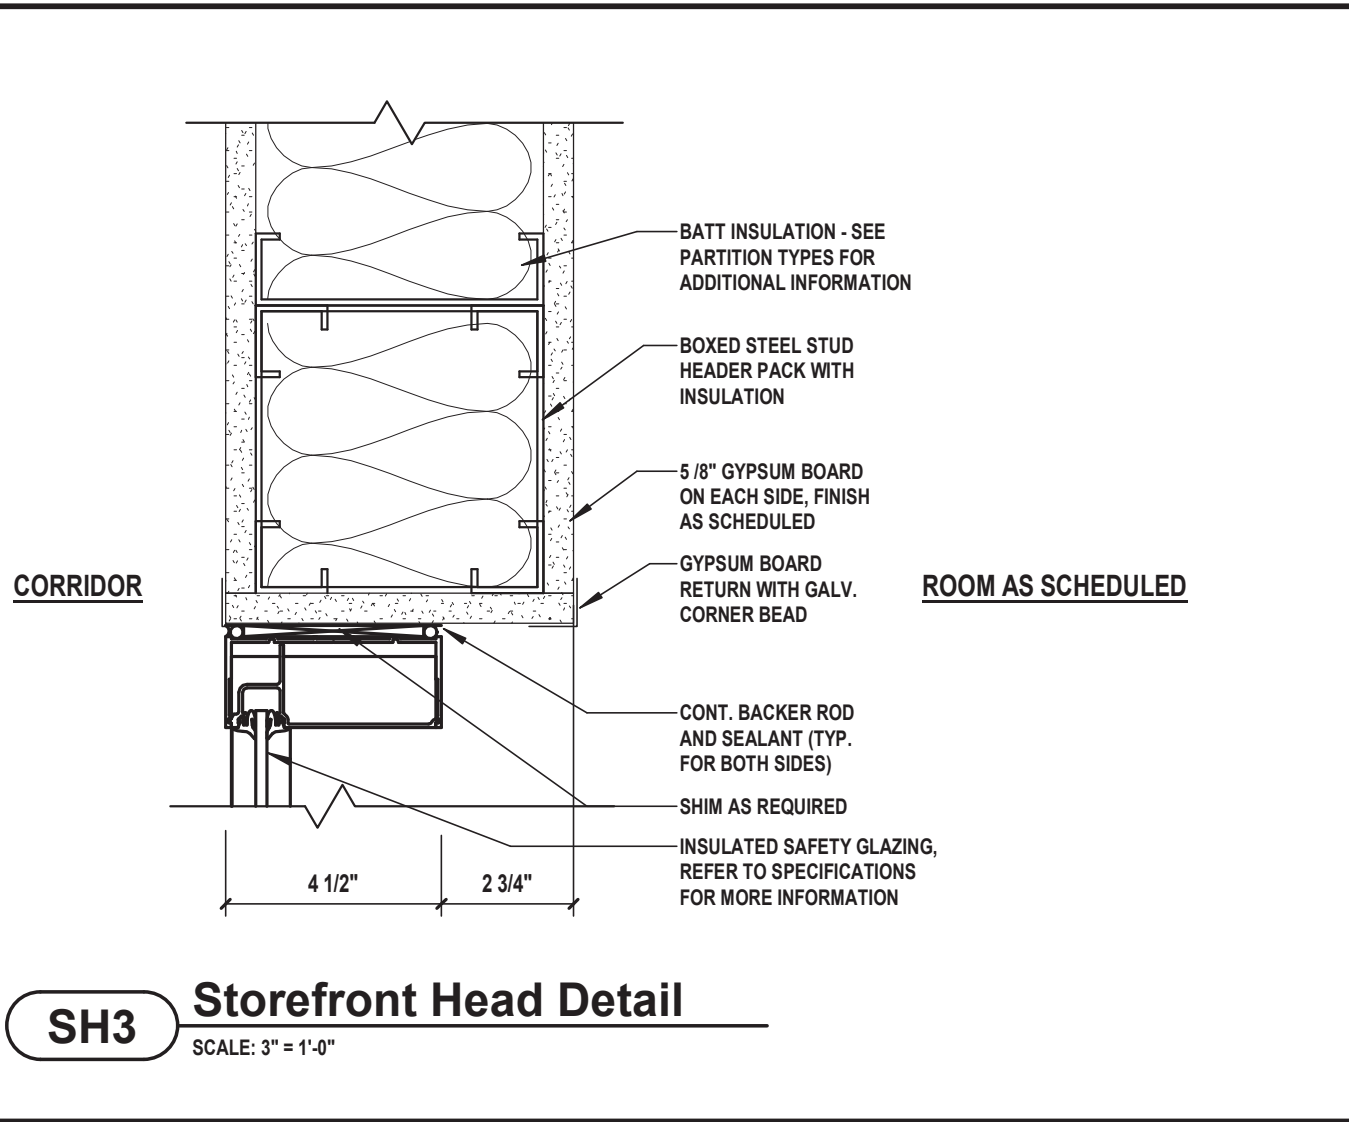


SH3 Storefront Head Detail

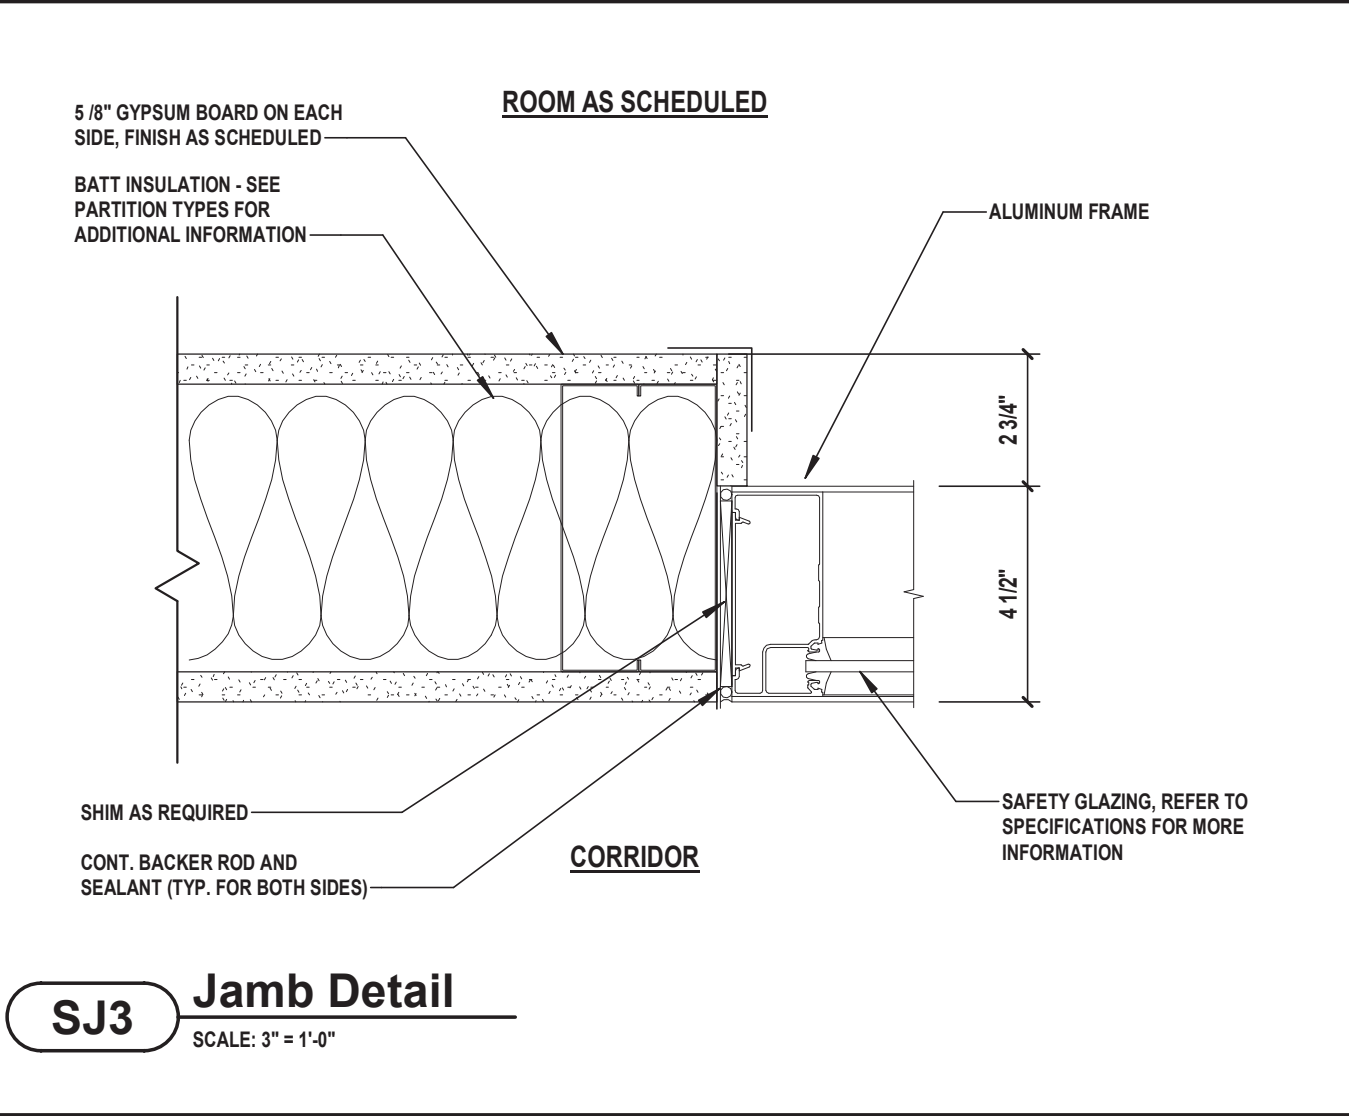


SJ3 Jamb Detail

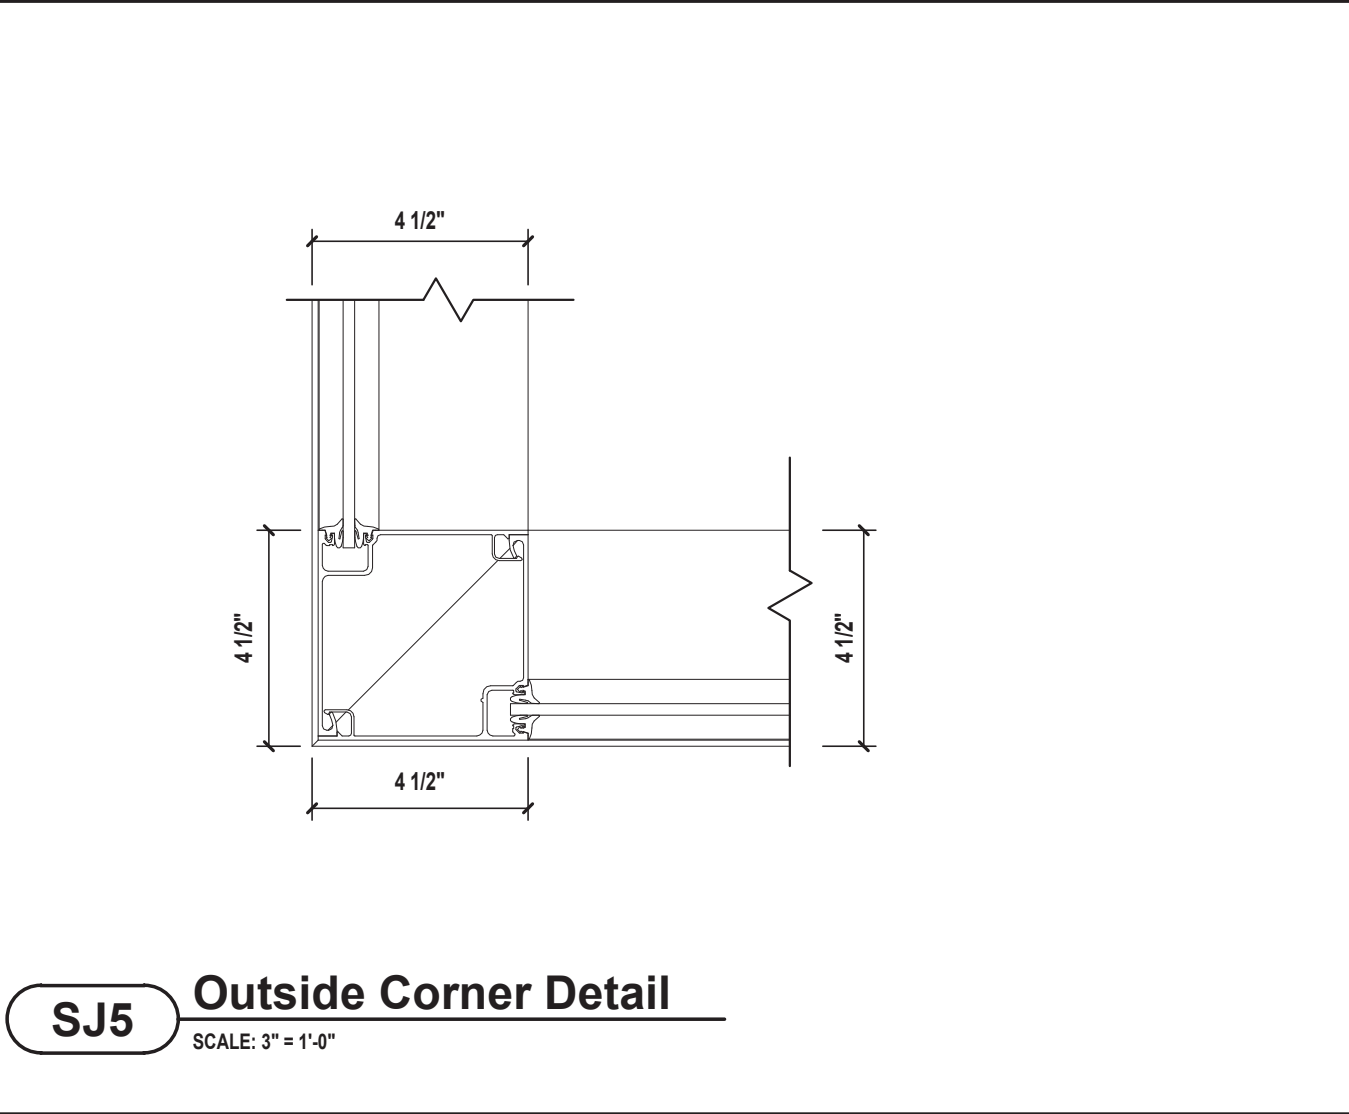


SS5 Sill Detail

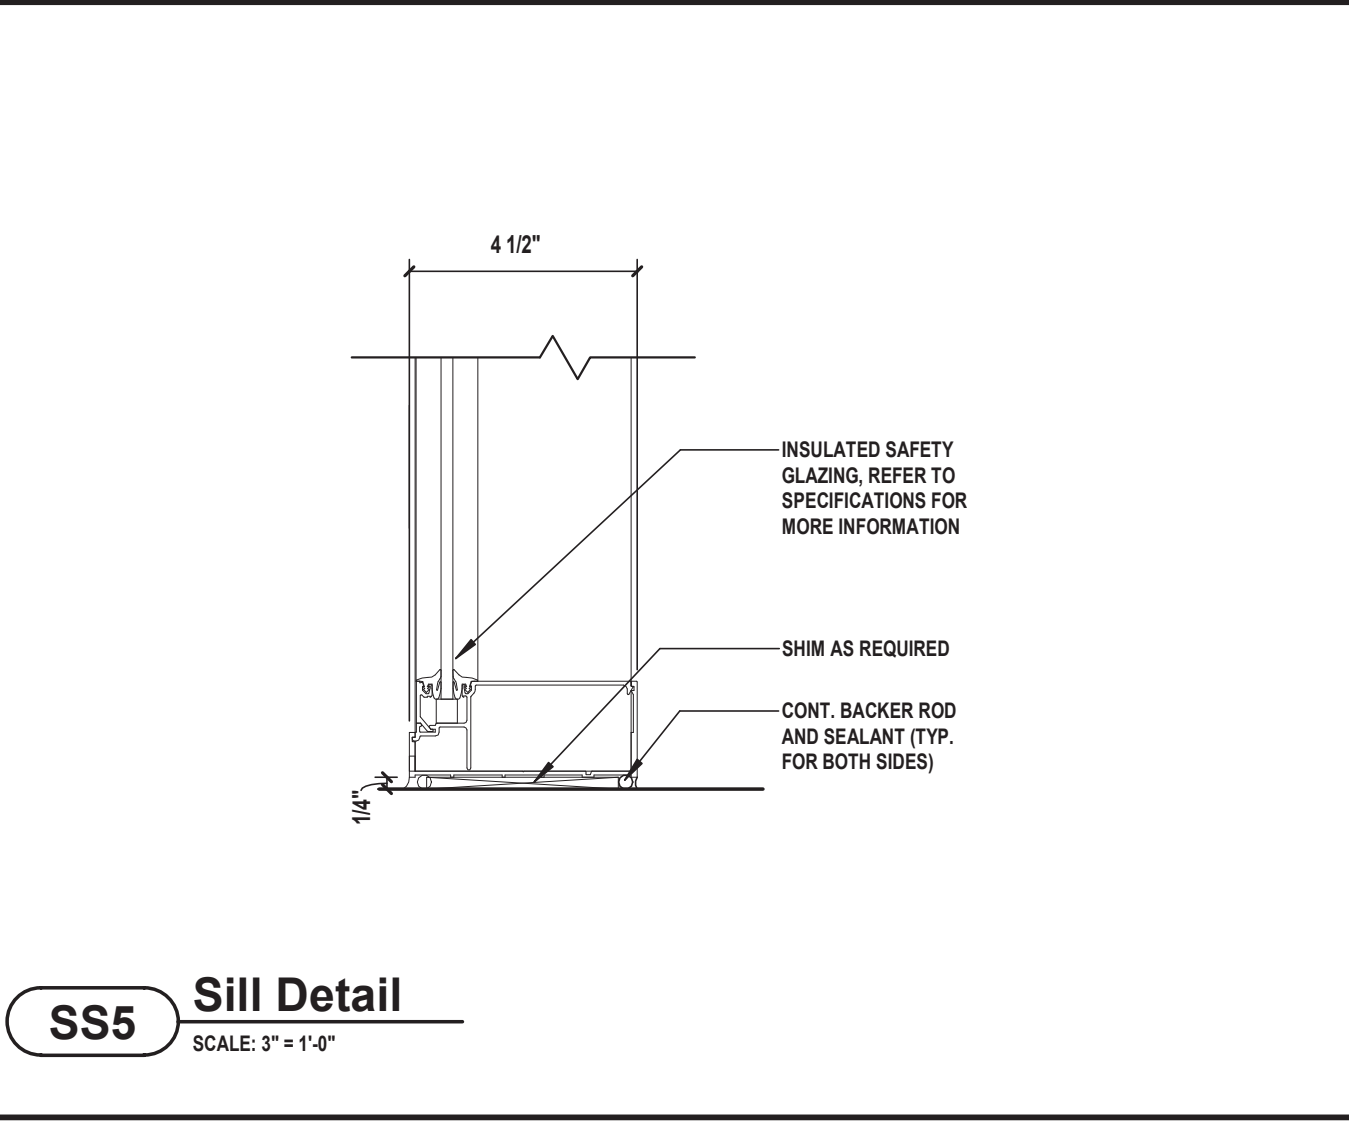


SS5 Sill Detail

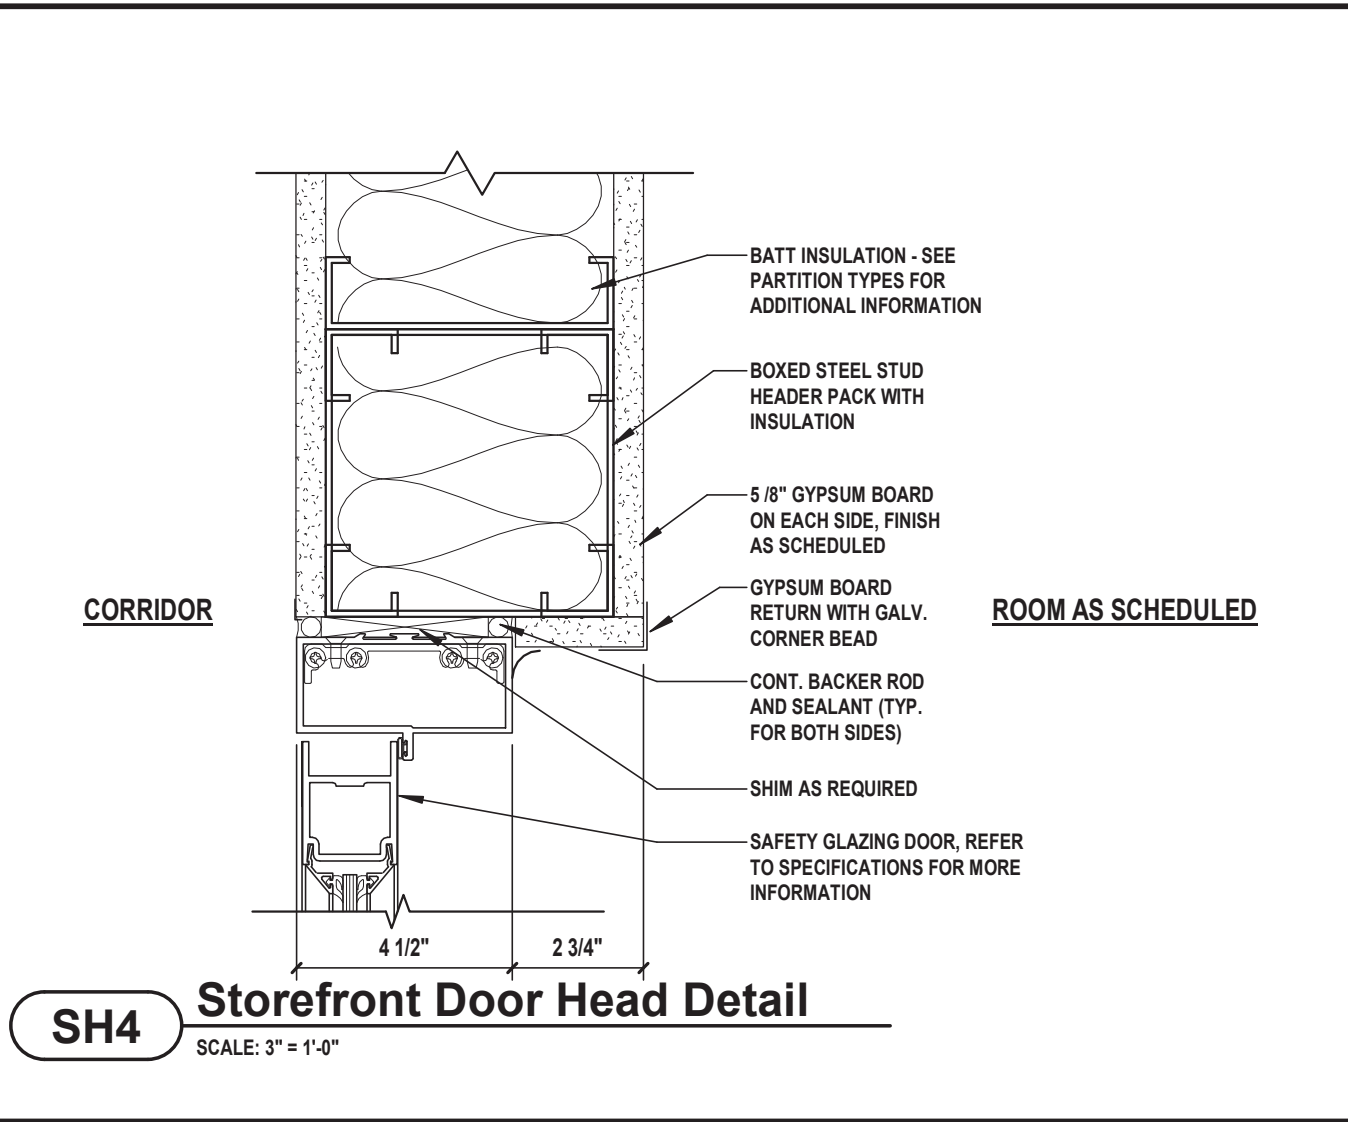


SH4 Storefront Door Head Detail

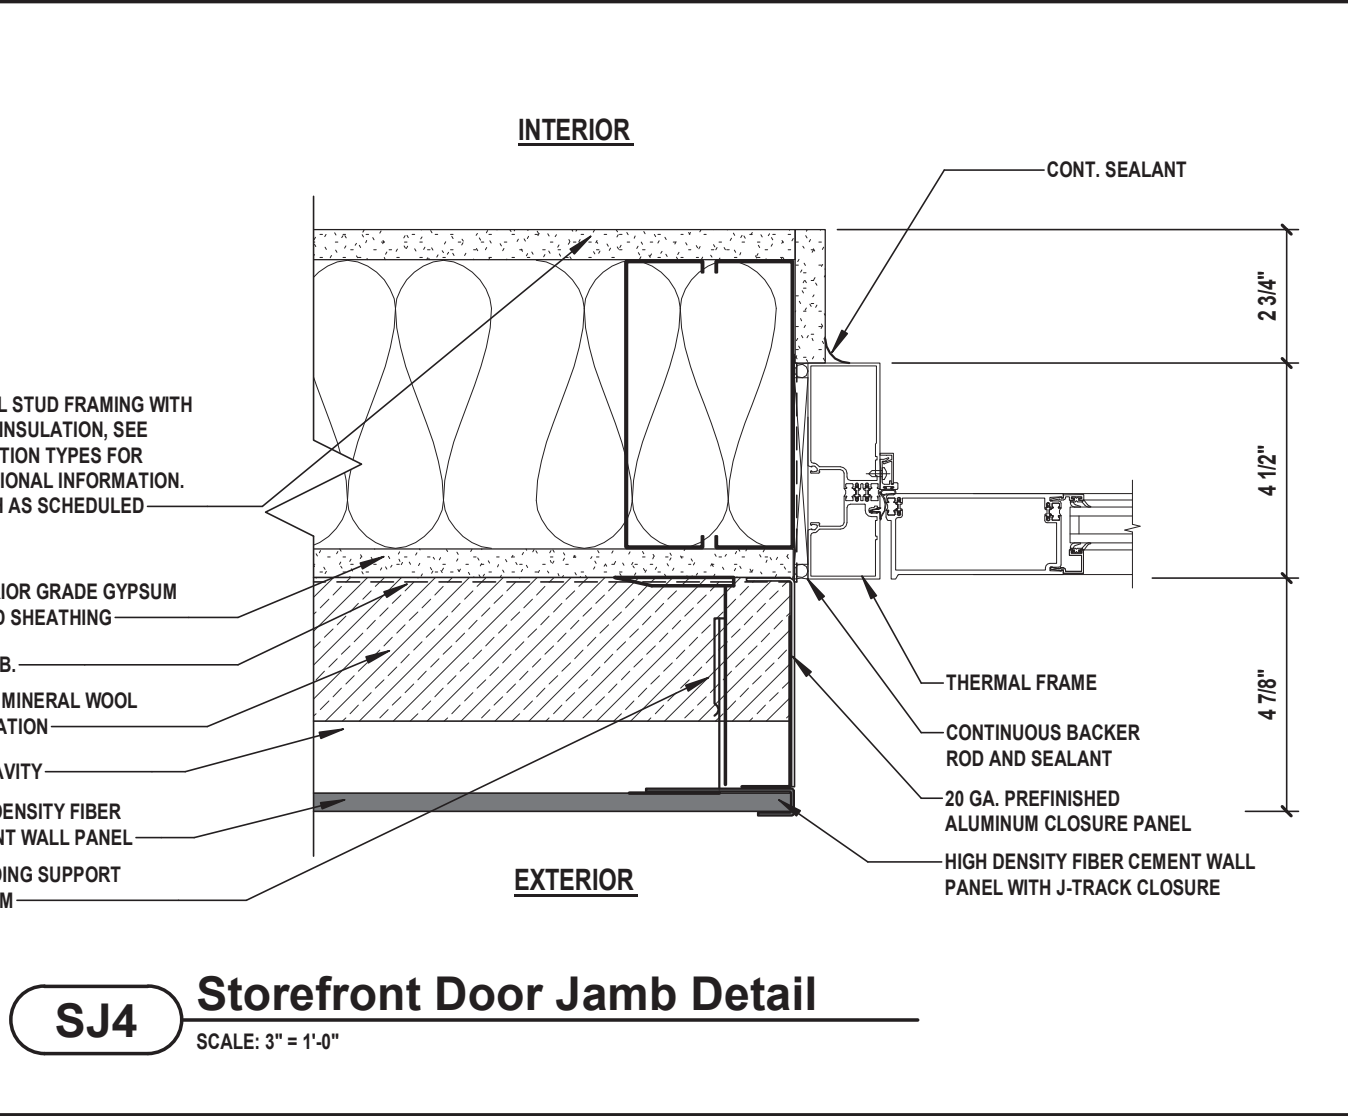

SJ4 Storefront Door Jamb Detail

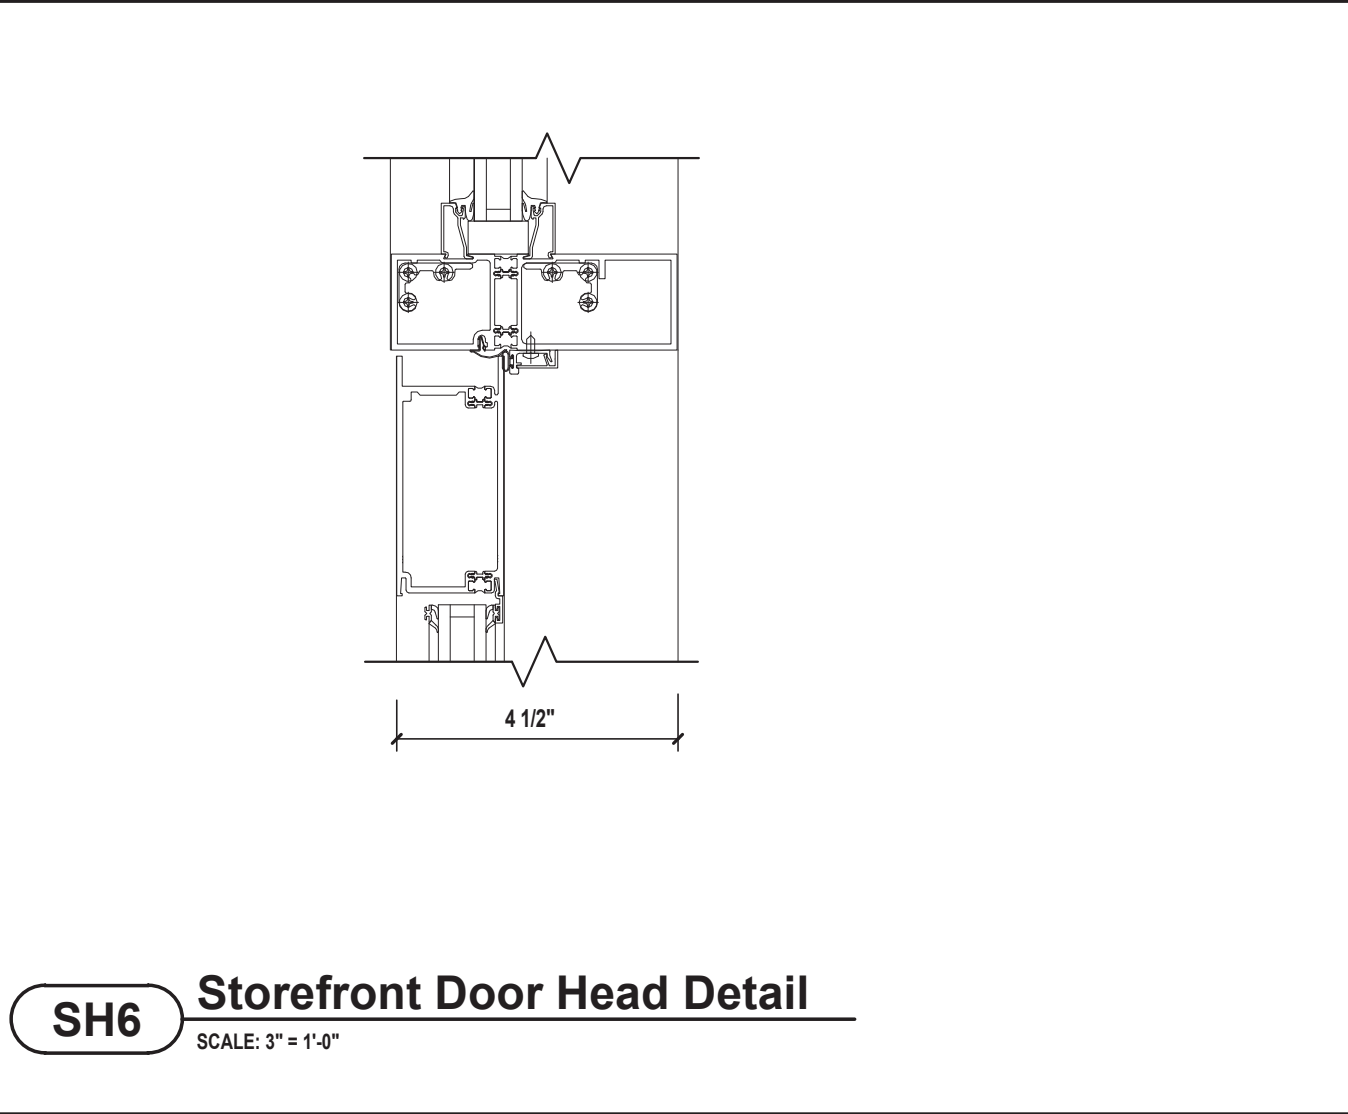

SH6 Storefront Door Head Detail

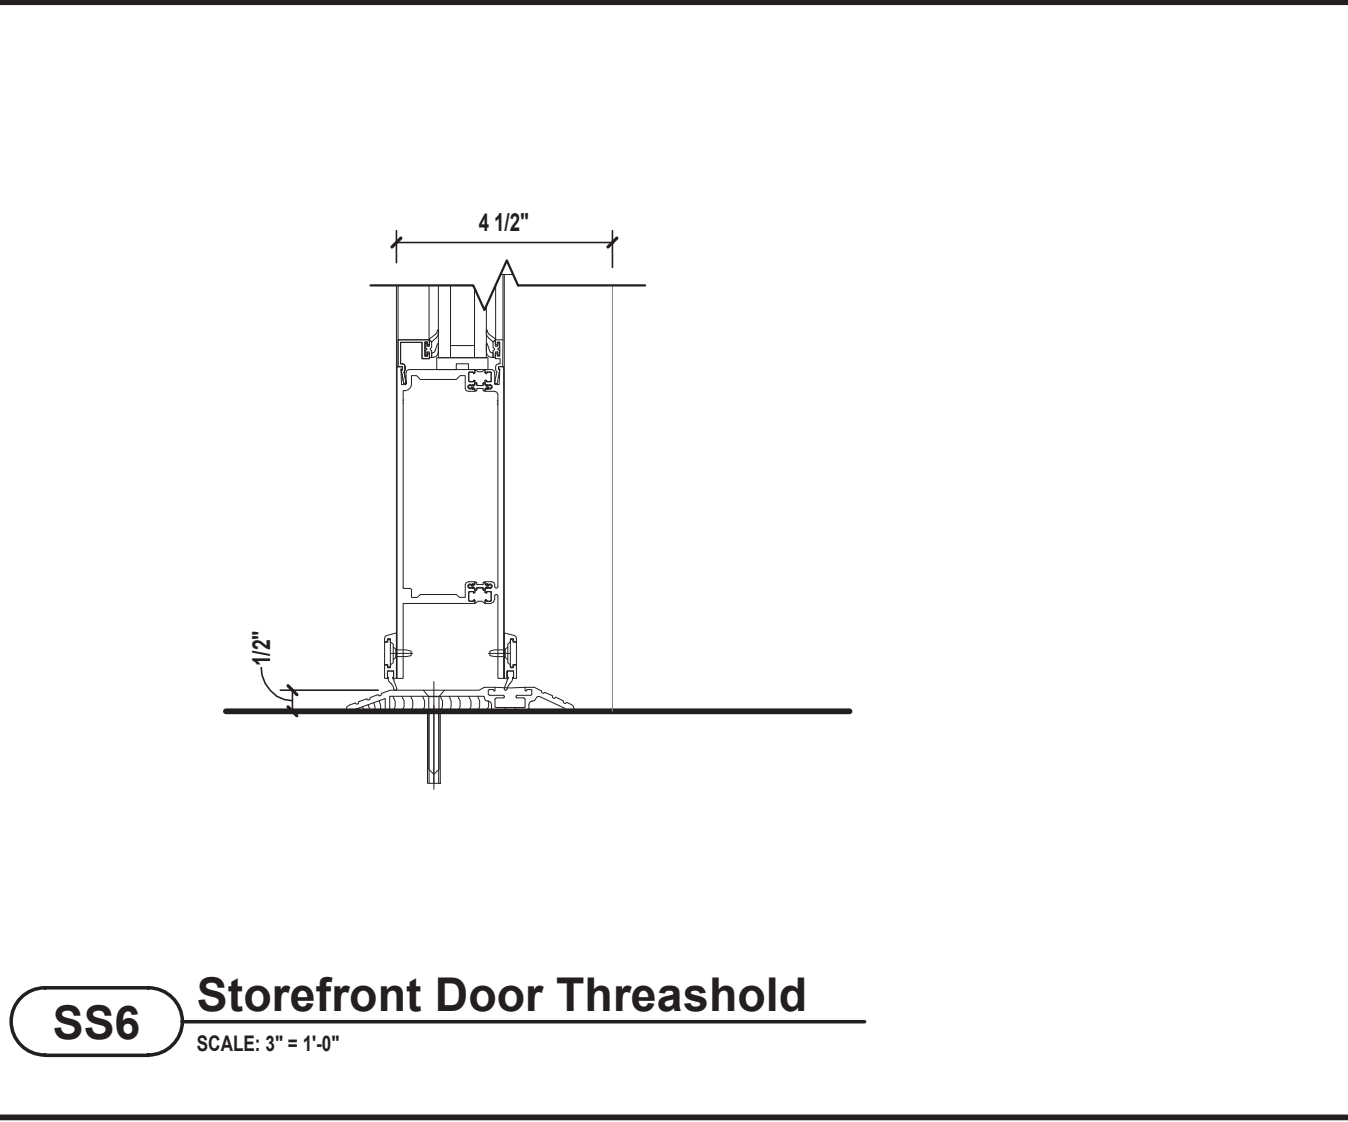

SS6 Storefront Door Threshold

MARK	DATE	DESCRIPTION